
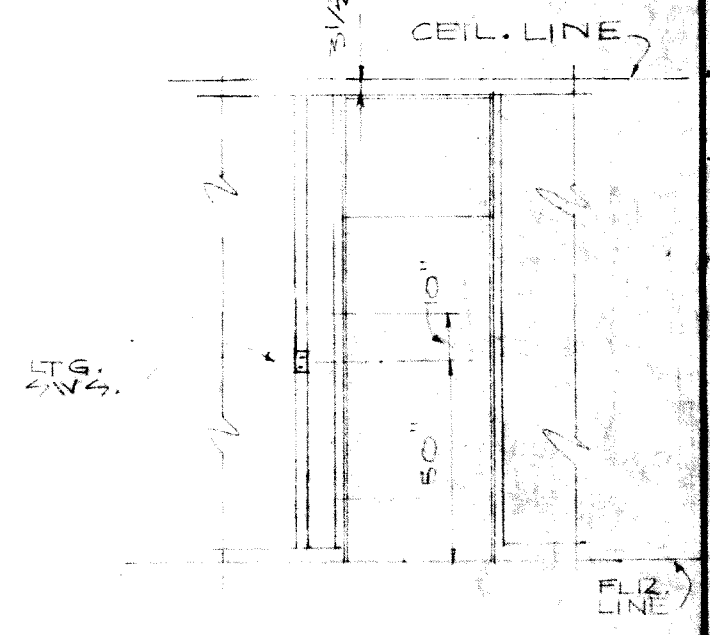



NO.	DESCRIPTION	DATE	BY
1	REVISION		
2	REVISION		
3	REVISION		
4	REVISION		
5	REVISION		

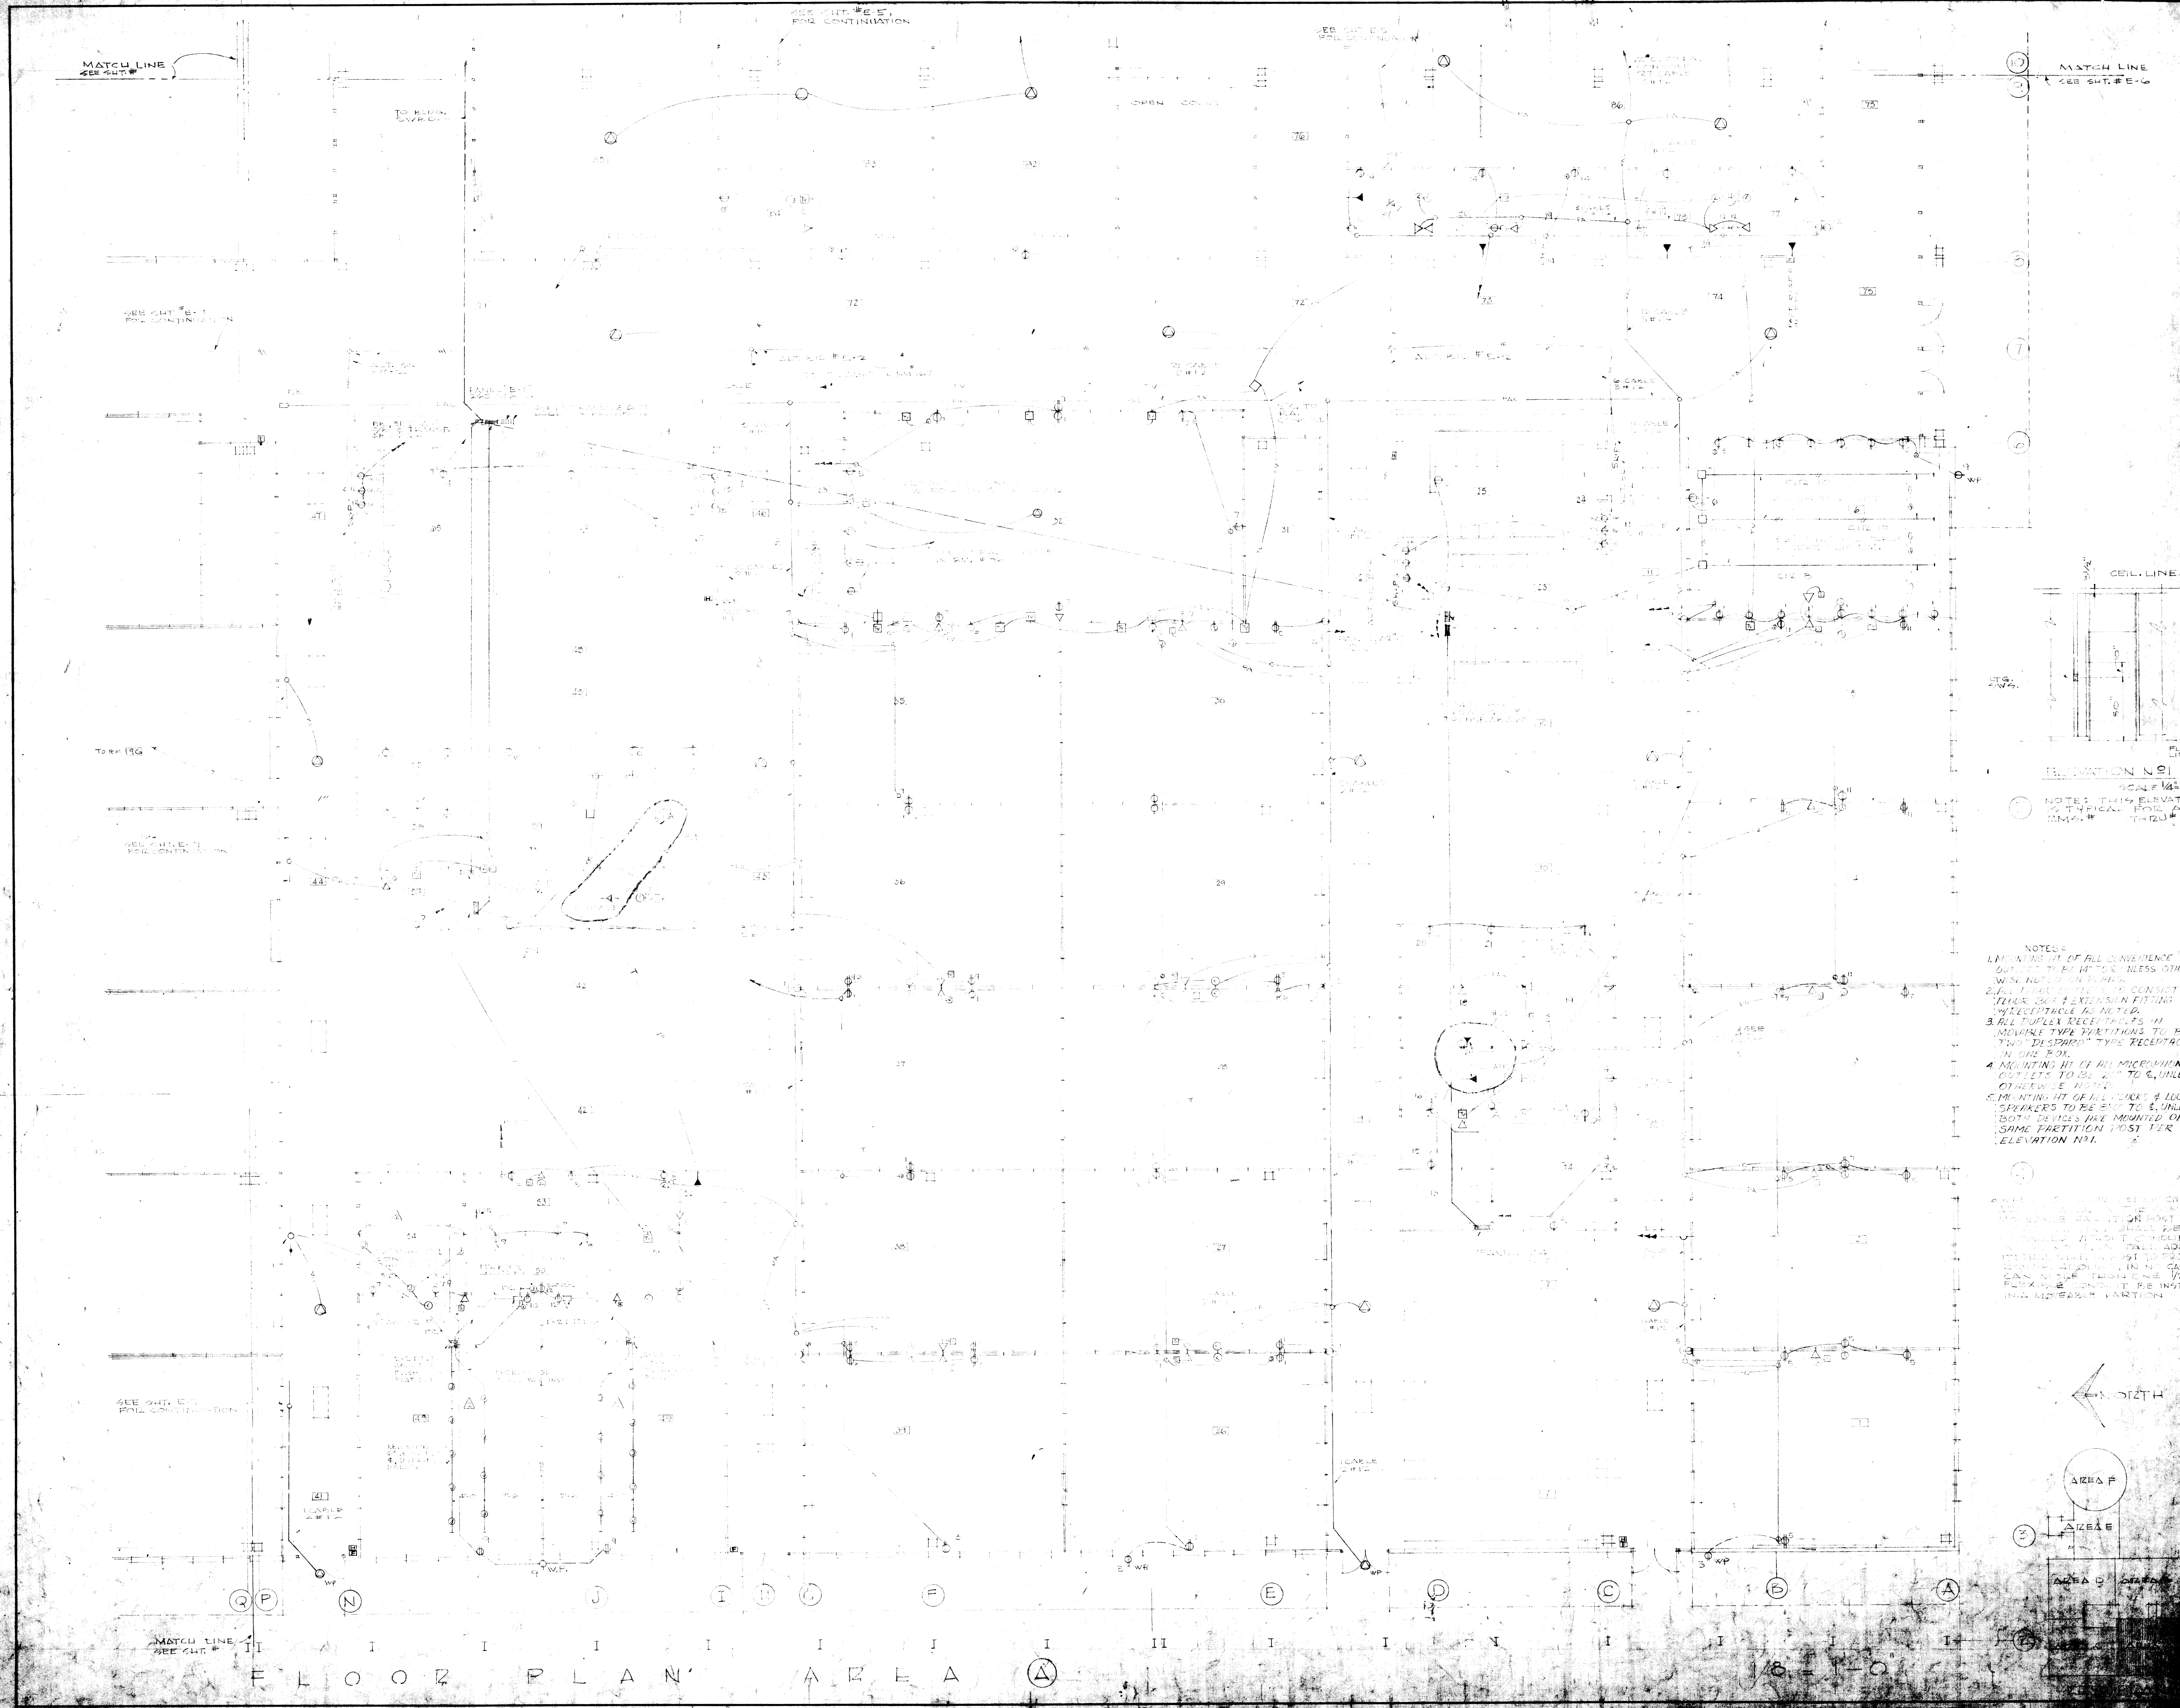

NOTE: THIS ELEVATION IS TYPICAL FOR ALL ROOMS THROUGHOUT.

- NOTES:
1. MOUNTING HT. OF ALL CONCEALED OUTLETS TO BE 18" UNLESS OTHERWISE NOTED.
 2. ALL TRUNK OUTLETS TO CONSIST OF 1/2" DIA. EXTENSION FITTING RECEPTACLE AS NOTED.
 3. ALL DUPLEX RECEPTACLES IN MOVABLE TYPE PARTITIONS TO BE TWO "DISCARD" TYPE RECEPTACLES IN ONE BOX.
 4. MOUNTING HT. OF ALL MICROPHONE OUTLETS TO BE 20" UNLESS OTHERWISE NOTED.
 5. MOUNTING HT. OF ALL CLOCKS & LUD-SPRINKERS TO BE 5' 7 1/2" UNLESS BOTH DEVICES ARE MOUNTED ON SAME PARTITION POST PER ELEVATION N 91.

CONSTRUCTION NOTES:
 ALL PARTITIONS TO BE 1/2" THICK
 ALL PARTITIONS TO BE 1/2" THICK
 ALL PARTITIONS TO BE 1/2" THICK
 ALL PARTITIONS TO BE 1/2" THICK

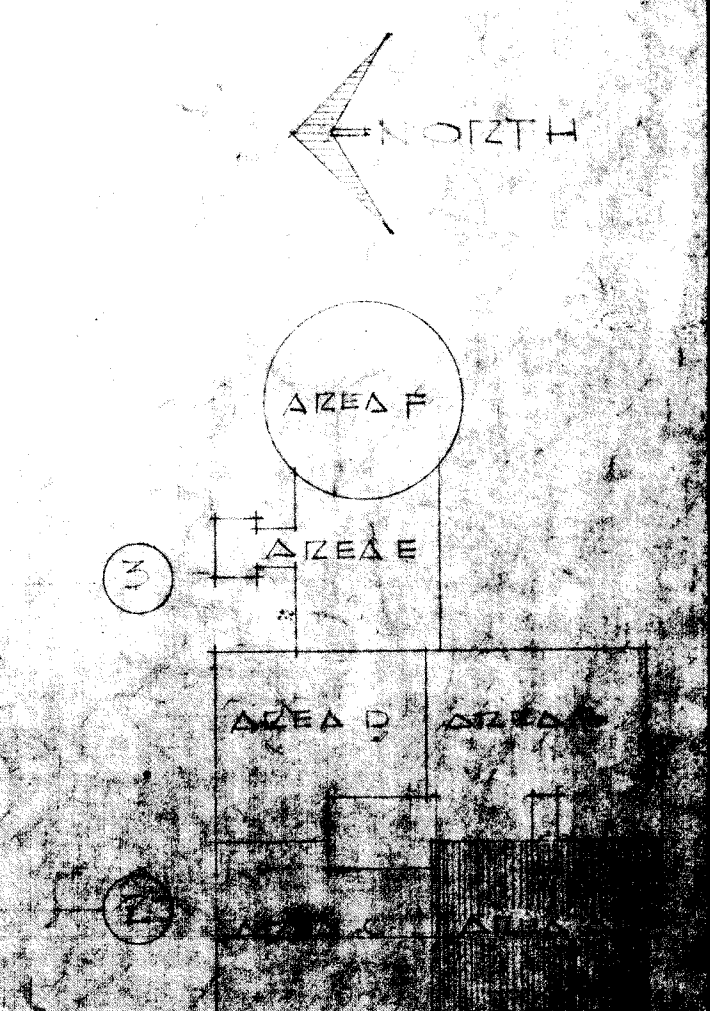



NOTE: CHIL. CONTINUITY
FOR CHIL. CONT. TIME
DO NOT TRIP

SEE CHIL. CONT.
FOR CONTINUITY

CHIL. CONT.
FOR CONTINUITY

SEE CHIL. CONT. FOR
CONTINUITY TO CHIL. CONT.
DO NOT TRIP

FILE NO. 943
DRAWN BY JMC
DATE 10/1/74
REV. COTZ

SHEET NUMBER
E-4
OF 5 SHEETS

LAWRENCE CENTRAL
SENIOR HIGH SCHOOL
MARION COUNTY, INDIANA

3344 MEADOWS DRIVE
MARIETTA, INDIANA 47556

NO.	DATE	BY	REVISION
1	10/1/74	JMC	1.0

1/8" = 1'-0"

AREA A

AREA B

AREA C

AREA D

AREA E

AREA F

AREA G

AREA H

AREA I

AREA J

AREA K

AREA L

AREA M

AREA N

AREA O

AREA P

AREA Q

AREA R

AREA S

AREA T

AREA U


AREA V

AREA W

AREA X

AREA Y

AREA Z

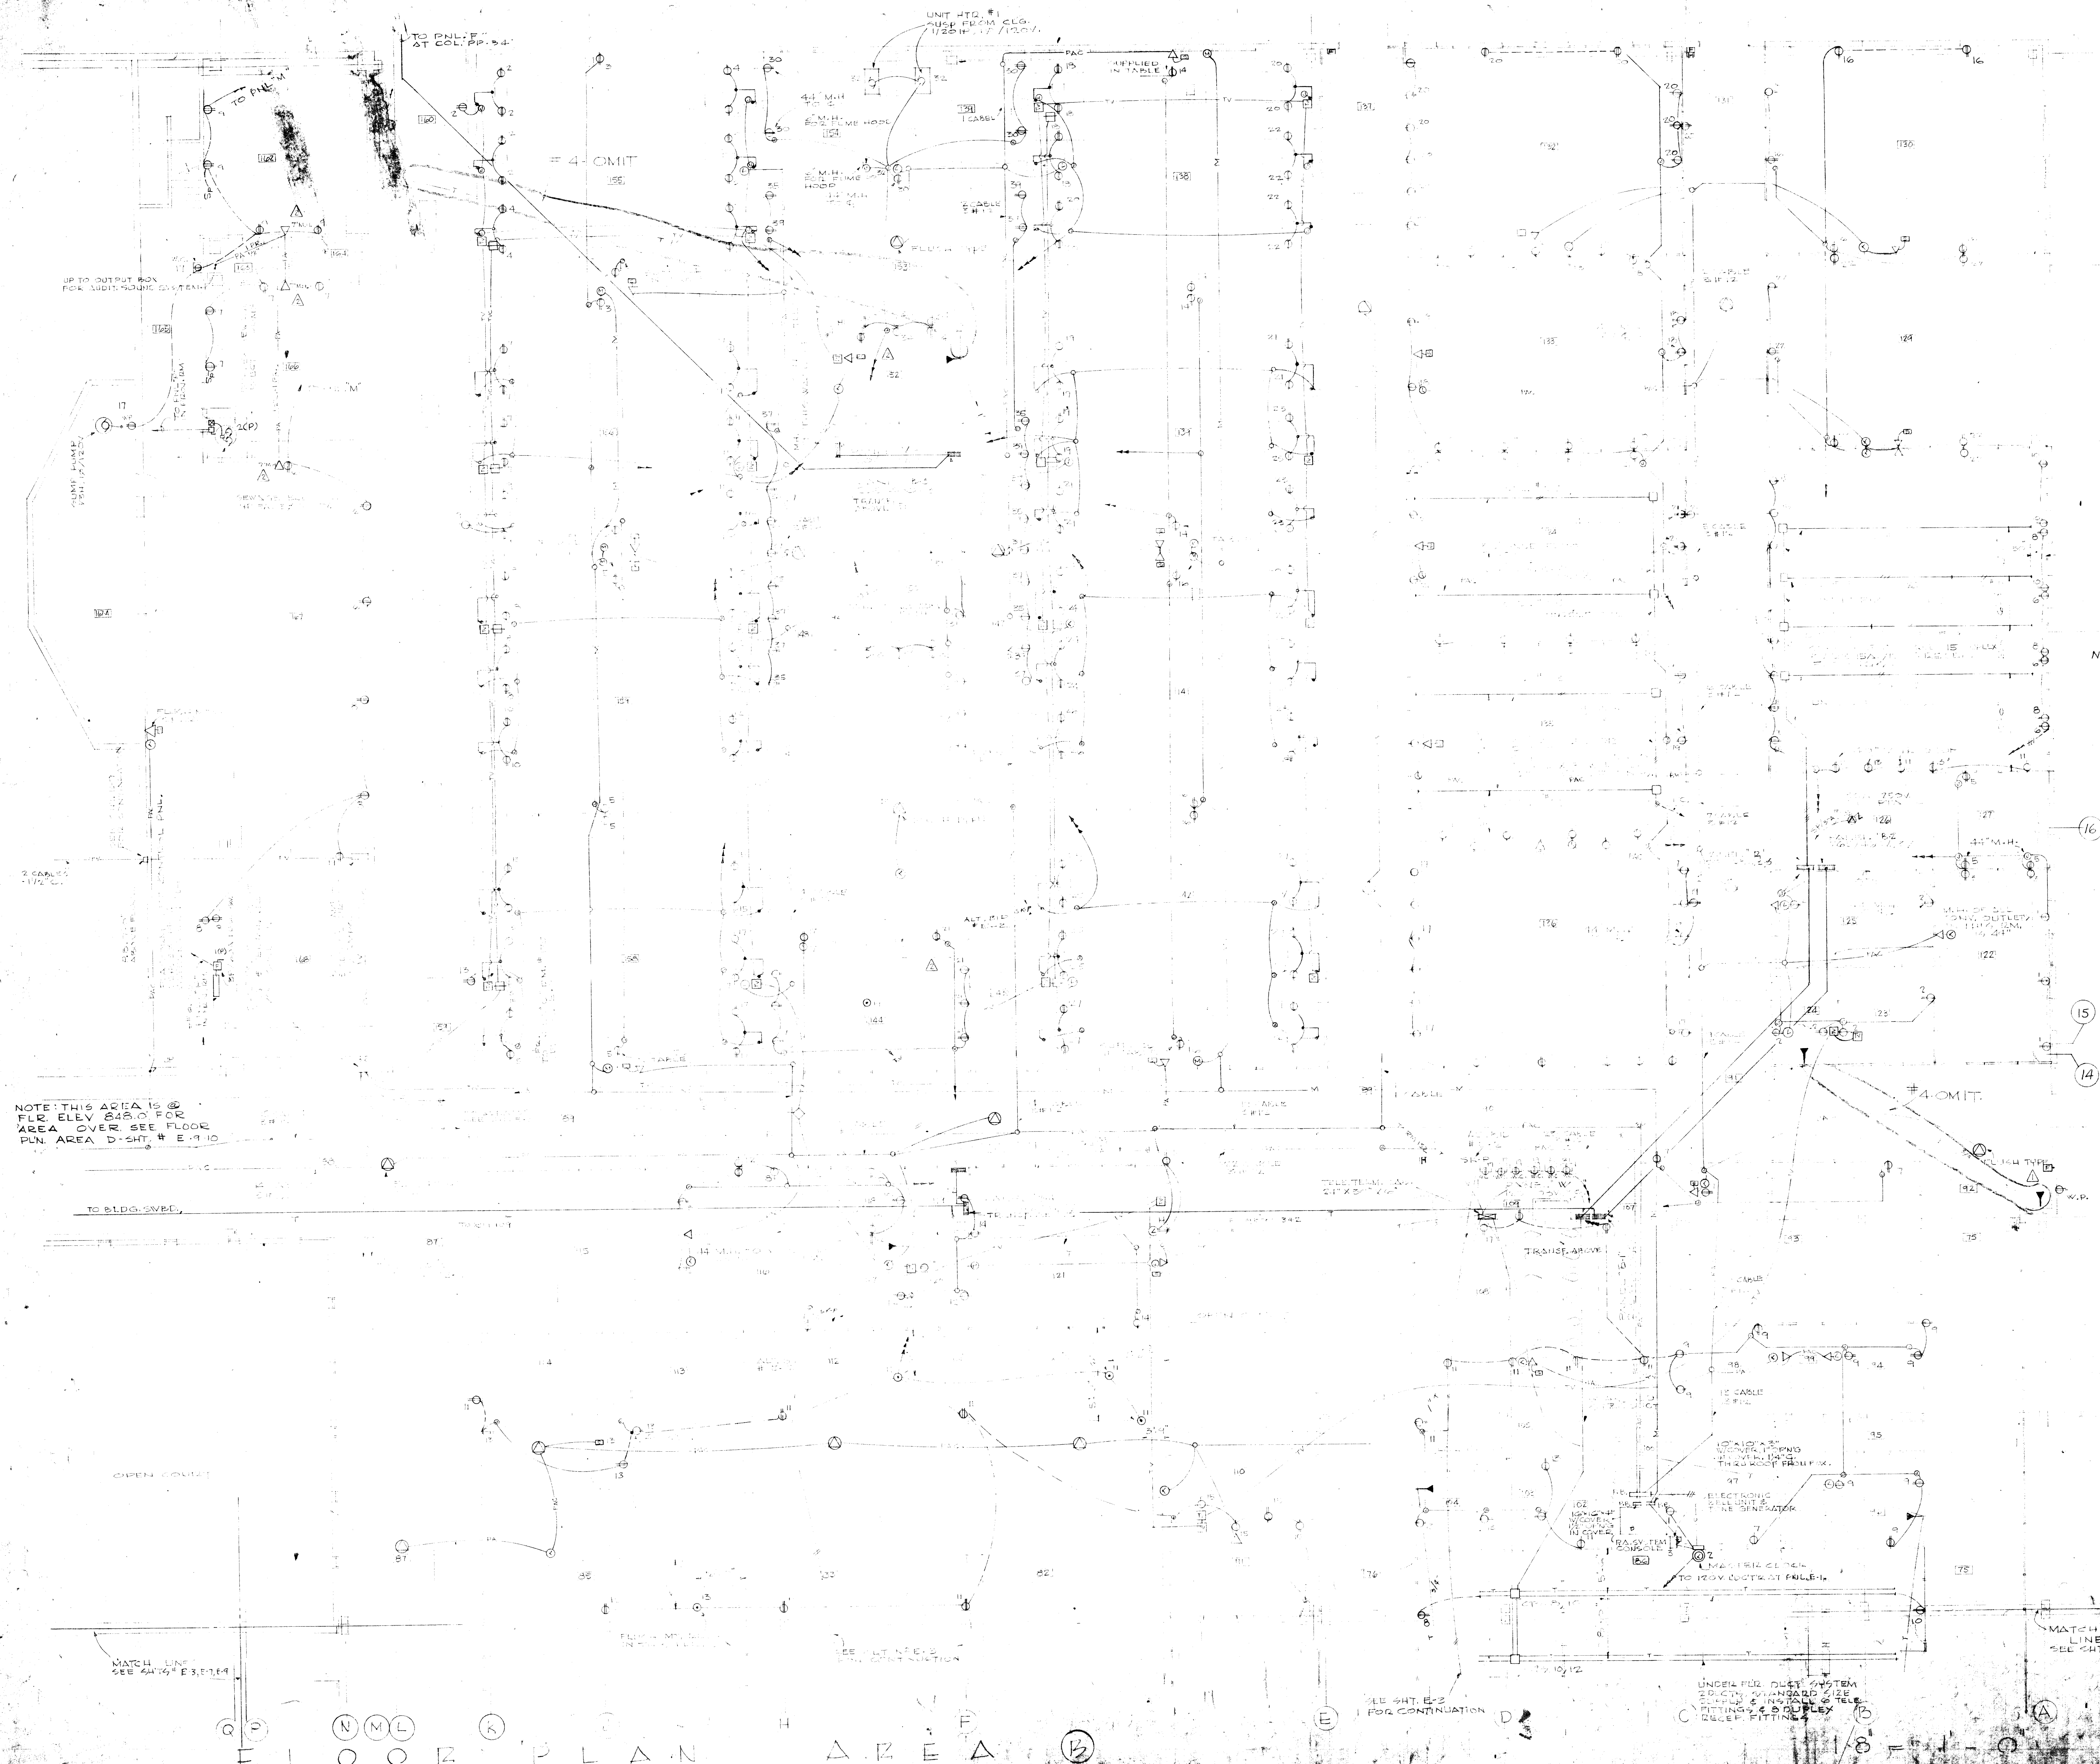

NOTES:

1. MOUNTING HT. OF ALL CONVENIENCE OUTLETS TO BE 14" TO & UNLESS OTHERWISE NOTED ON PLANS.
2. ALL FLOOR OUTLETS TO COME WITH FLOOR PLATE & EXTENSION FITTING IF RECEPTACLE IS NOTED.
3. ALL DUPLEX RECEPTACLES IN MOVABLE TYPE PARTITIONS TO BE 2" W/ 2" DEPENDENT RECEPTACLES IN ONE BOX.
4. MOUNTING HT. OF ALL MICROPHONE OUTLETS TO BE 20" TO & UNLESS OTHERWISE NOTED.
5. MOUNTING HT. OF ALL CUBICLE LOUDSPEAKERS TO BE 8" TO & UNLESS BOTH DEVICES ARE MOUNTED ON SAME PARTITION POST PER ELEVATION N°1.

6. WHERE 277 V. CIR. @ 120V CIR. ARE LOCATED IN THE SAME MOVABLE PARTITION POST, THE 120V CIR. WIZING SHALL BE INSTALLED WITH THE 277V CIR. IN THE POST. INSTALL ADDITIONAL WIRE IN POSTS TO PROVIDE SEPARATE CIRCUITS IN NO CASE CAN MORE THAN ONE 17' FLEXIBLE CABLE BE INSTALLED IN ANY MOVABLE PARTITION POST.

3429 MEADOWS DRIVE
INDIANAPOLIS 5, INDIANA

APR 11 1962

LAWRENCE CENTRAL
SENIOR HIGH SCHOOL
MARION COUNTY, INDIANA


FLOOR PLAN AREA "B"

SHEET NUMBER
E - 5

OF SHEETS

FILE NO. 943
DRAWN BY CMC
DATE 7/29/62
REV. CCR

NO.	DESCRIPTION	DATE	BY
1	REVISIONS		
2	REVISIONS		
3	REVISIONS		
100	REVISIONS		

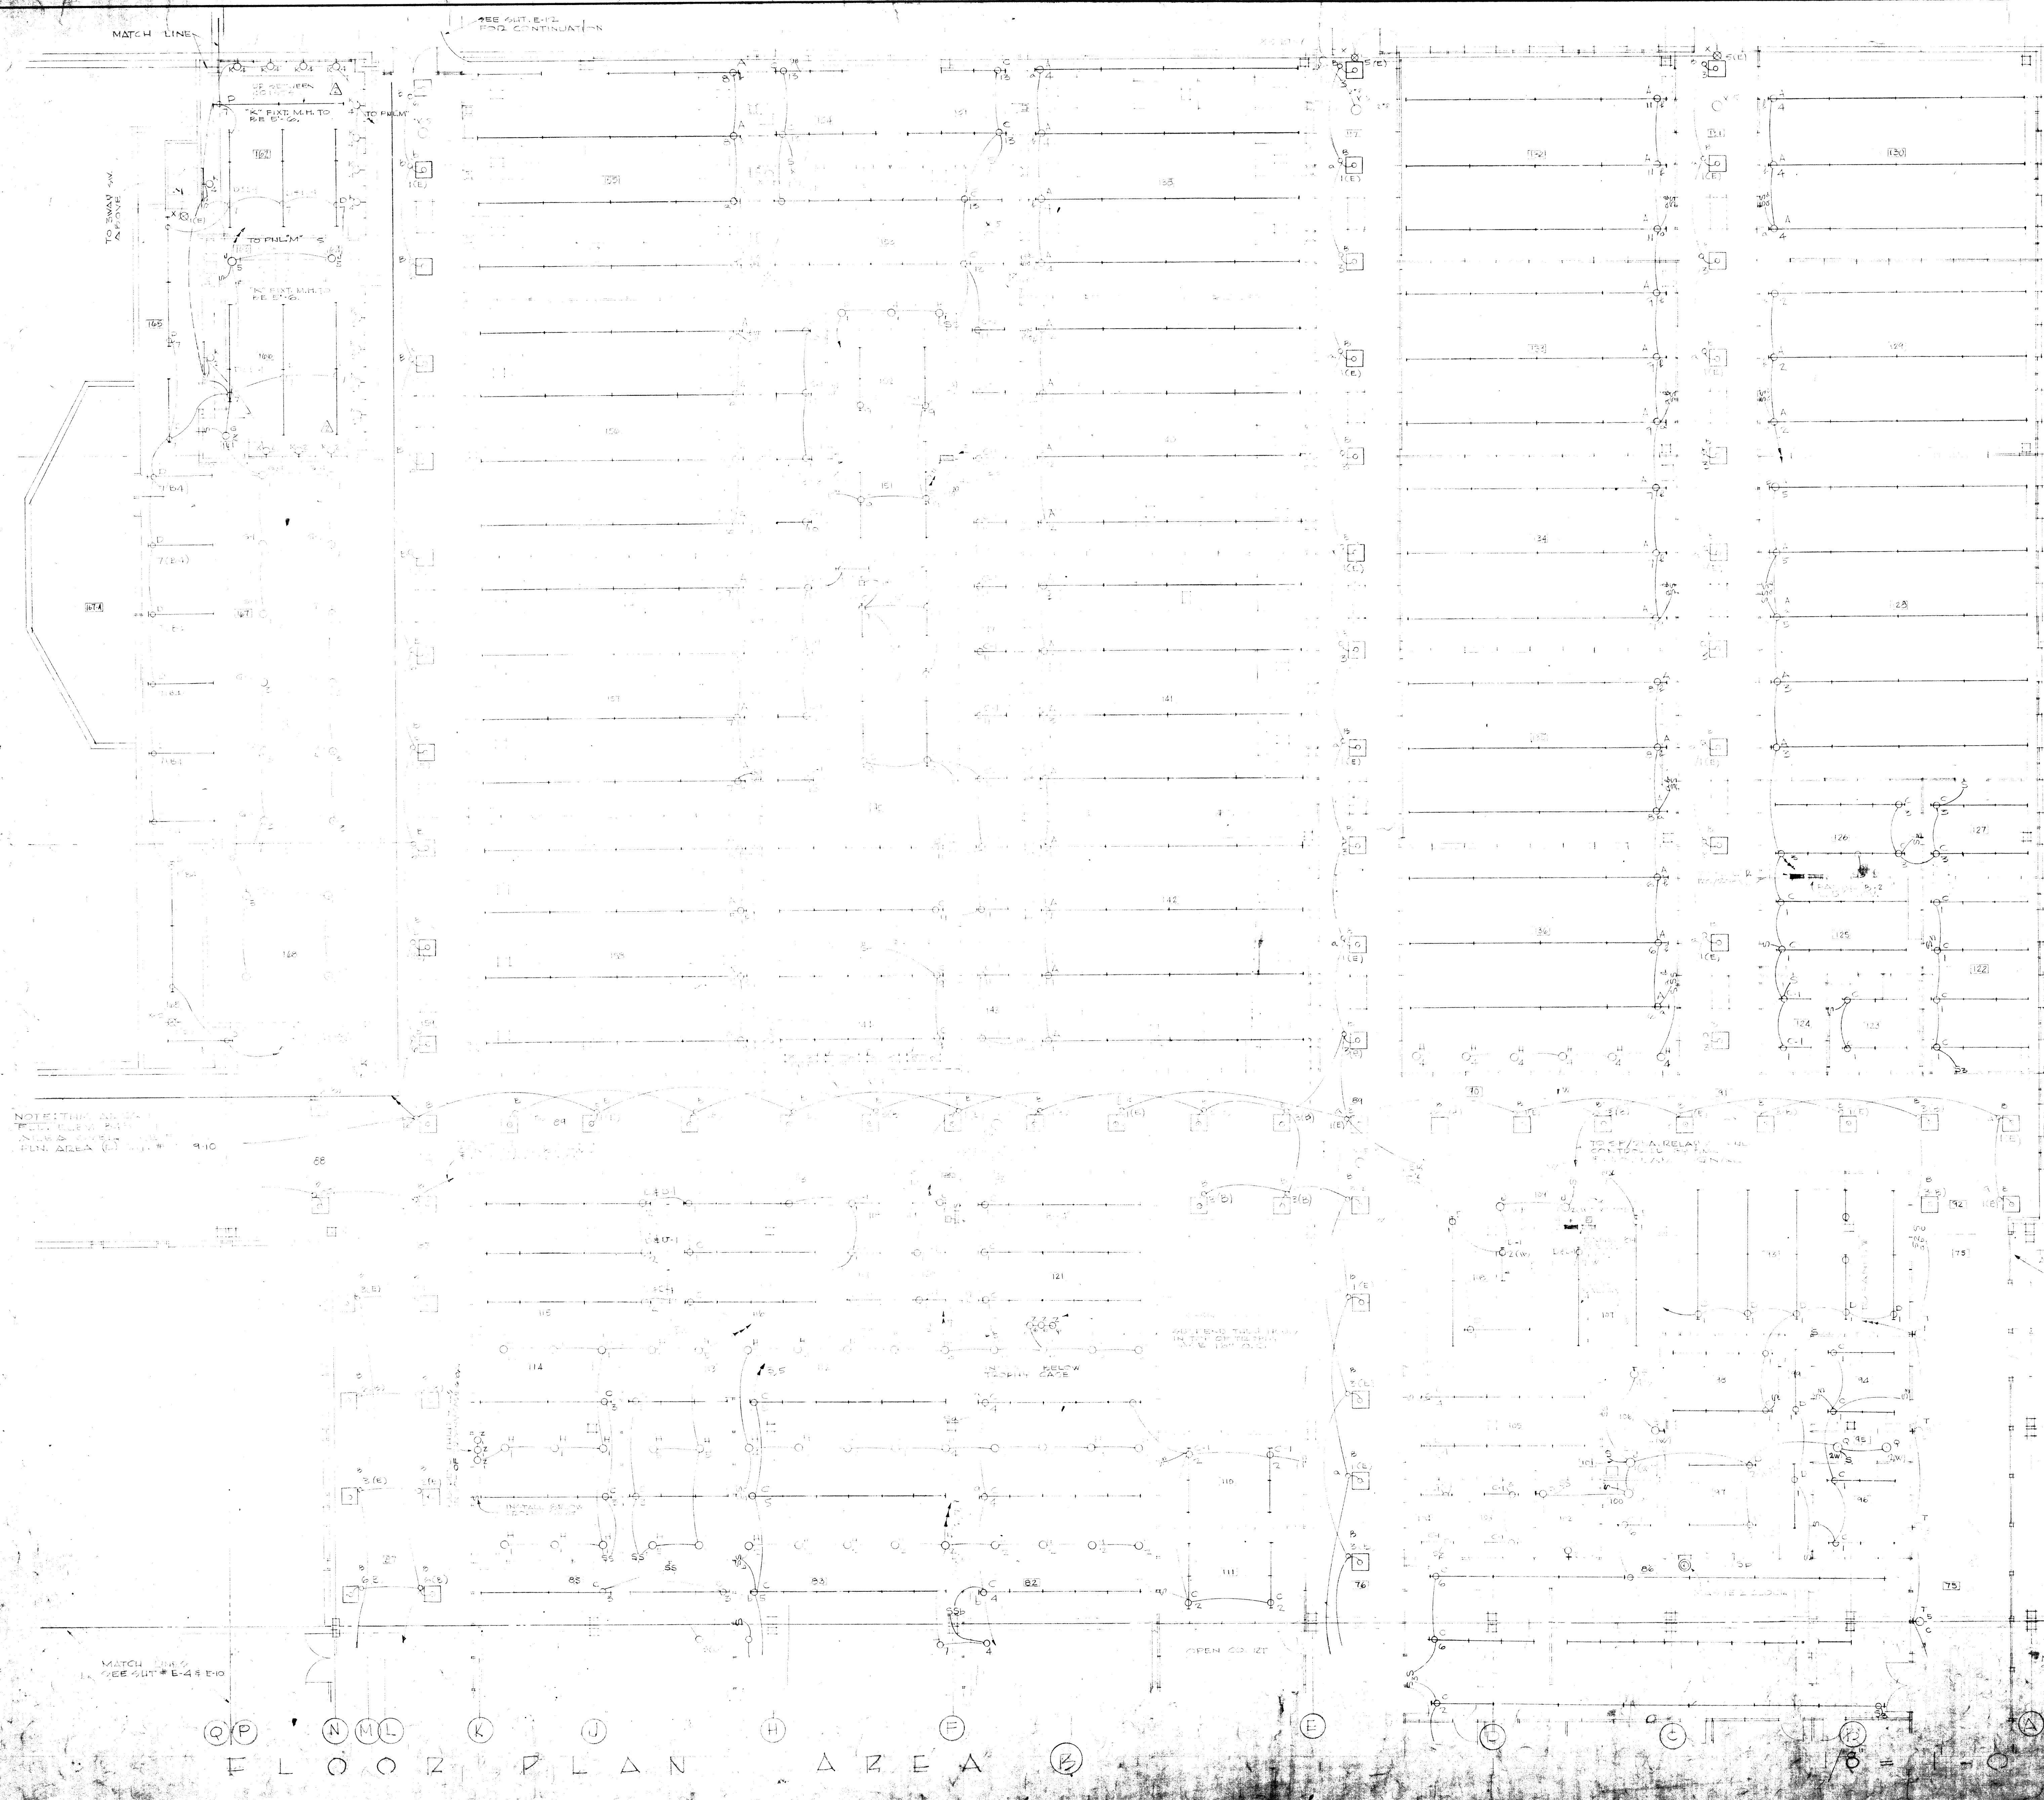

NOTE: THIS AREA IS
FOR ELEVATION
AND IS NOT TO BE
CONSIDERED AS A
PART OF THE
FLOOR AREA (SEE SHEET 9-10)

NOTES:
ALL UNLabeled SWITCHES IN
MOVABLE TYPE PARTITIONS TO
BE REPAIRED TYPE

TO TIME
U-1

MATCH LINE
SEE SHEET 9-4

FLOOR PLAN AREA B

← NORTH

AREA F

AREA E

AREA D

AREA C

AREA A

FILE NO. 943
DRAWN BY LMC
DATE 2/1/44
REV. 1/1/44

SHEET NUMBER
E-6
OF SHEETS

FLOOR PLAN AREA "B"


1	2	3	4	5	6	7	8	9	10	11	12	13	14	15	16	17	18	19	20

LAWRENCE CENTRAL
SENIOR HIGH SCHOOL
MARION COUNTY, INDIANA

3949 MEADOWS DRIVE
INDIANAPOLIS 4, INDIANA

Project Engineer
X-1000

943 E.C.

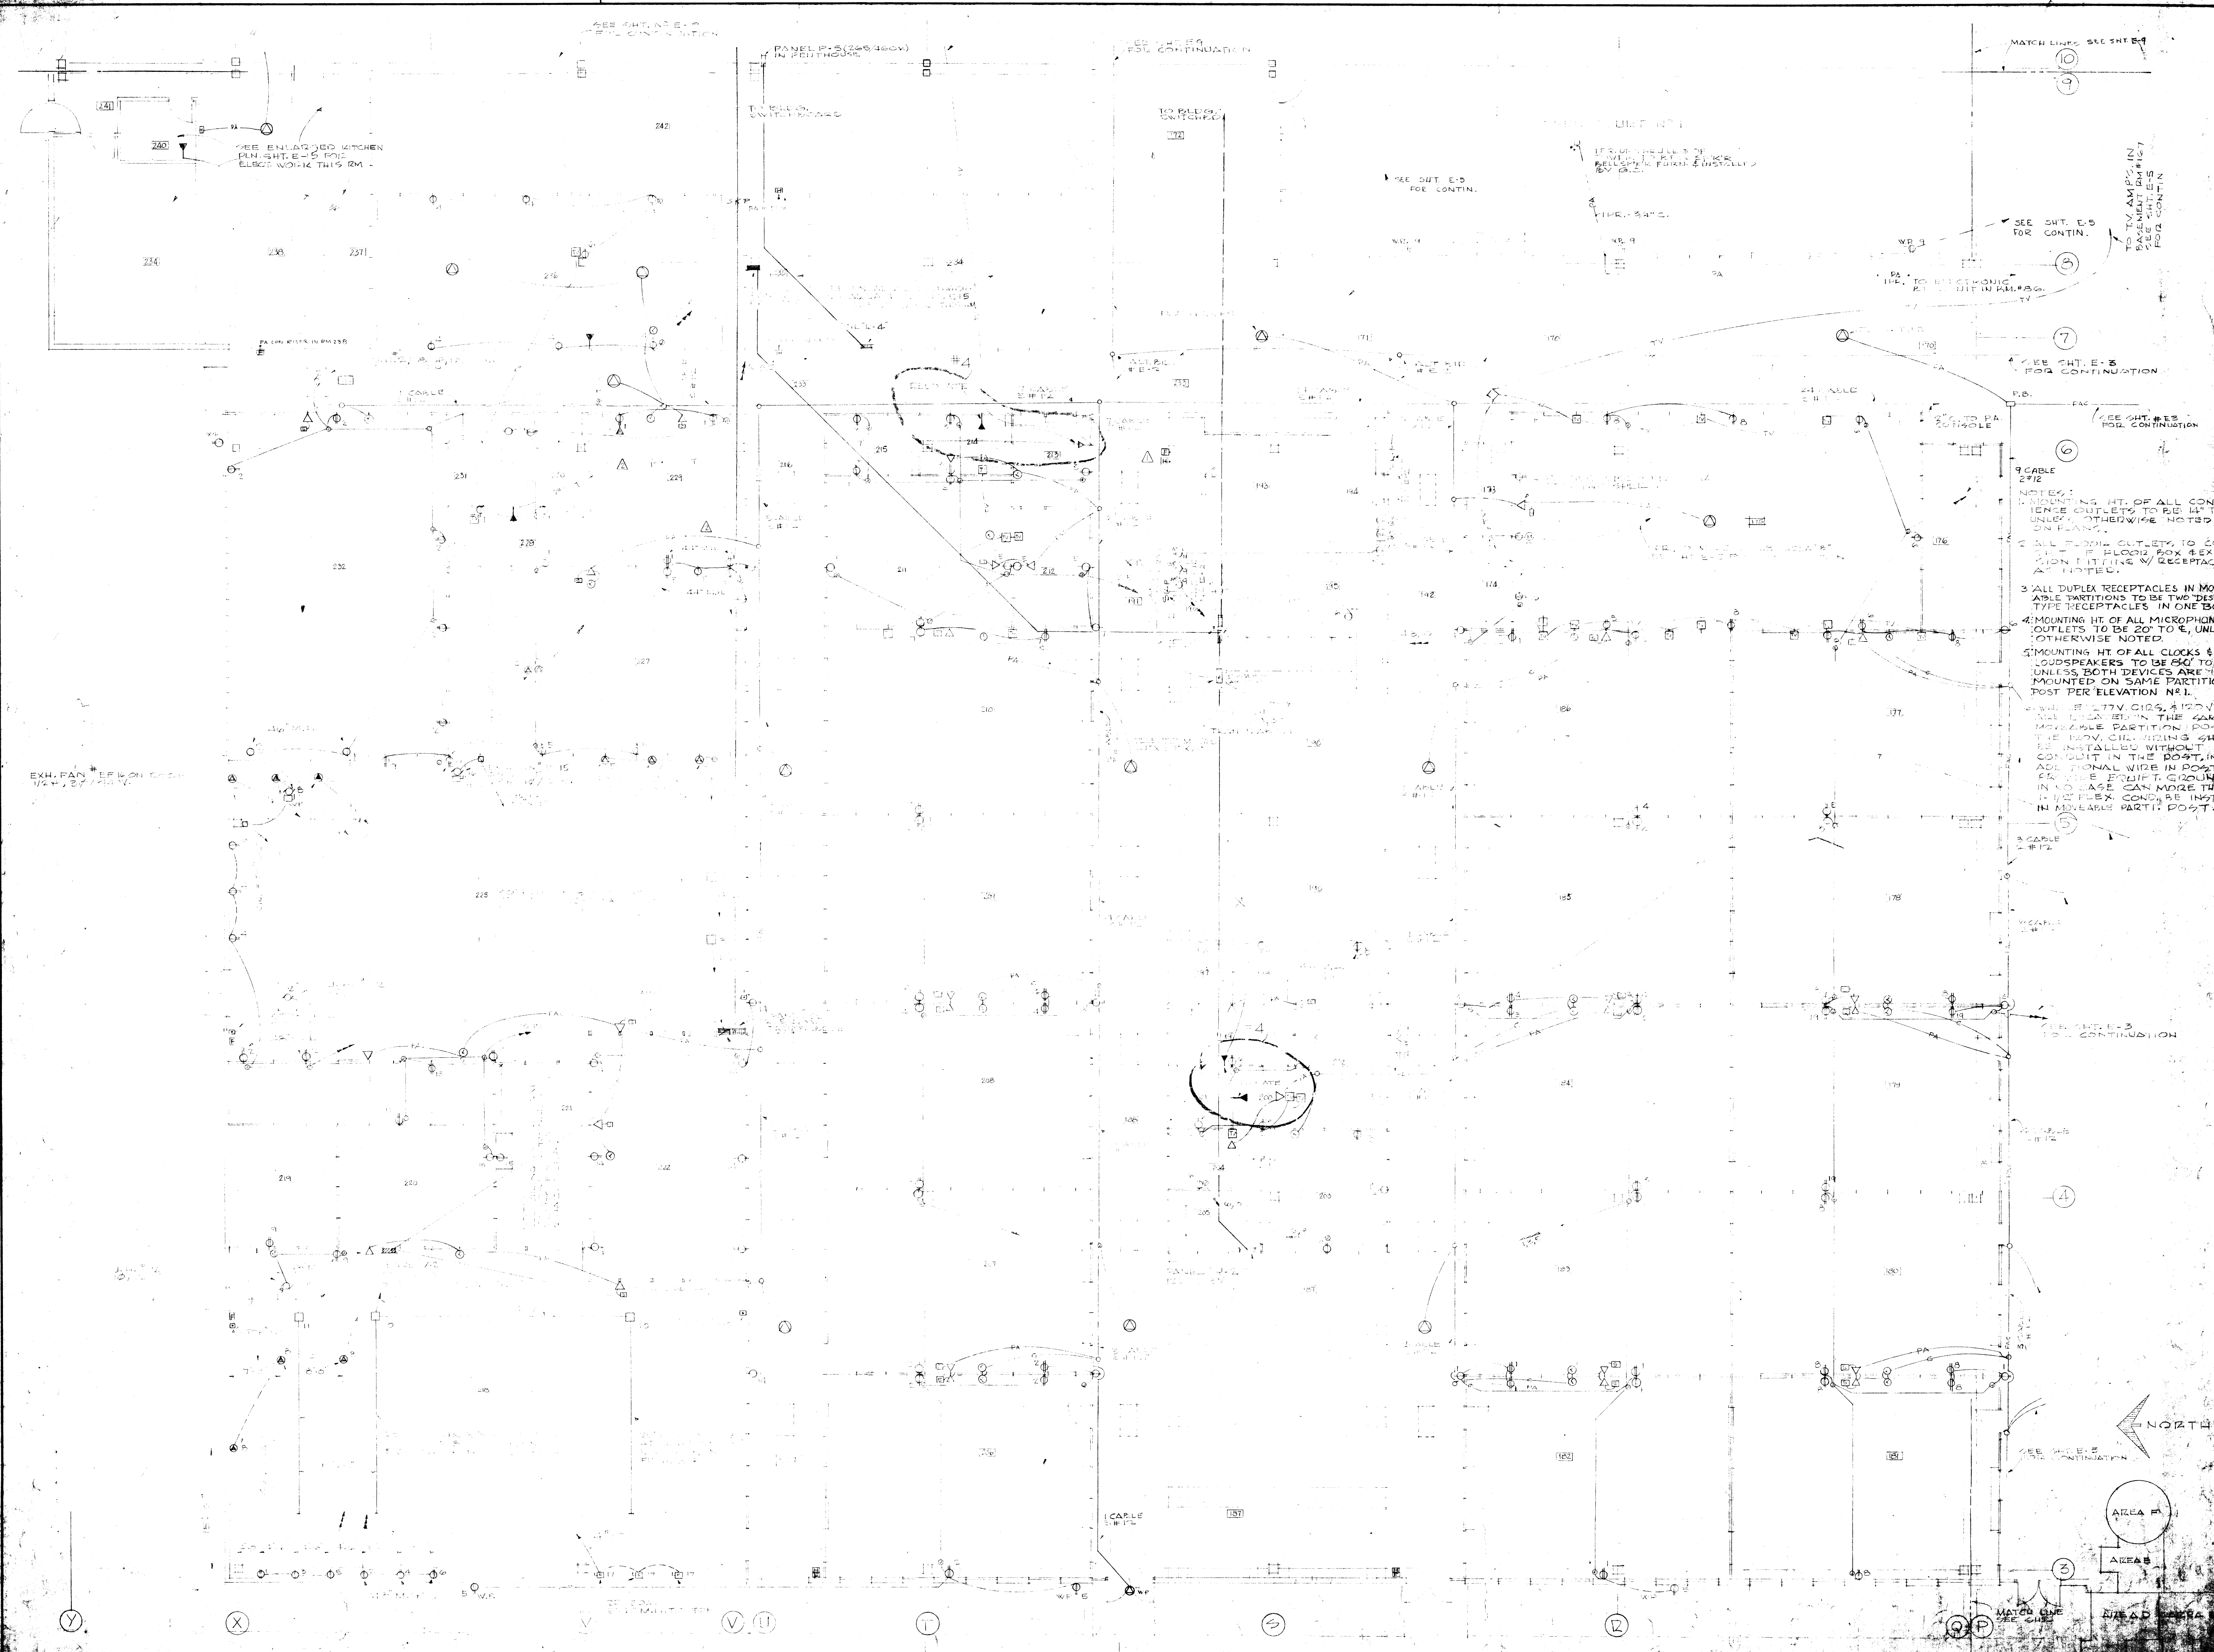


EXH. PAN. E-1 ON TOP OF
1/2" x 3/4" x 1/4" V.

F L O O R P L A N A R E A C

- NOTES:
1. MOUNTING HT. OF ALL CONVENIENCE OUTLETS TO BE 42" TO 48" UNLESS OTHERWISE NOTED ON PLANS.
 2. ALL DUPLEX OUTLETS TO CONDUIT IF FLOOR BOX EXTENDS DOWN FITTING W/ RECEPTACLE AS NOTED.
 3. ALL DUPLEX RECEPTACLES IN MOVABLE PARTITIONS TO BE TWO "DEMAND" TYPE RECEPTACLES IN ONE BOX.
 4. MOUNTING HT. OF ALL MICROPHONE OUTLETS TO BE 20" TO 48" UNLESS OTHERWISE NOTED.
 5. MOUNTING HT. OF ALL CLOCKS & LOUDSPEAKERS TO BE 60" TO 84" UNLESS BOTH DEVICES ARE MOUNTED ON SAME PARTITION POST PER ELEVATION NO. 1.
 6. ALL 110V CIG. & 110V VOLTAGE LOCATED IN THE SAME MOVABLE PARTITION POST. THE 110V CIG. WIRING SHALL BE INSTALLED WITHOUT CONDUIT IN THE POST, INSTALL ADDITIONAL WIRE IN POST TO EXCEED THE POST'S GROUND. IN NO CASE CAN MORE THAN ONE FLEX CONDUIT BE INSTALLED IN MOVABLE PART. POST.

FILE NO. 943	DRAWN BY D.H.C.	DATE 11/1/67	REV. 1/1/68
SHEET NUMBER E-7			
OF SHEETS			
FLOOR PLAN AREA "C"			
LAWRENCE CENTRAL SENIOR HIGH SCHOOL MARION COUNTY, INDIANA			
1545 W. SHADOWS DRIVE INDIANAPOLIS 5, INDIANA			

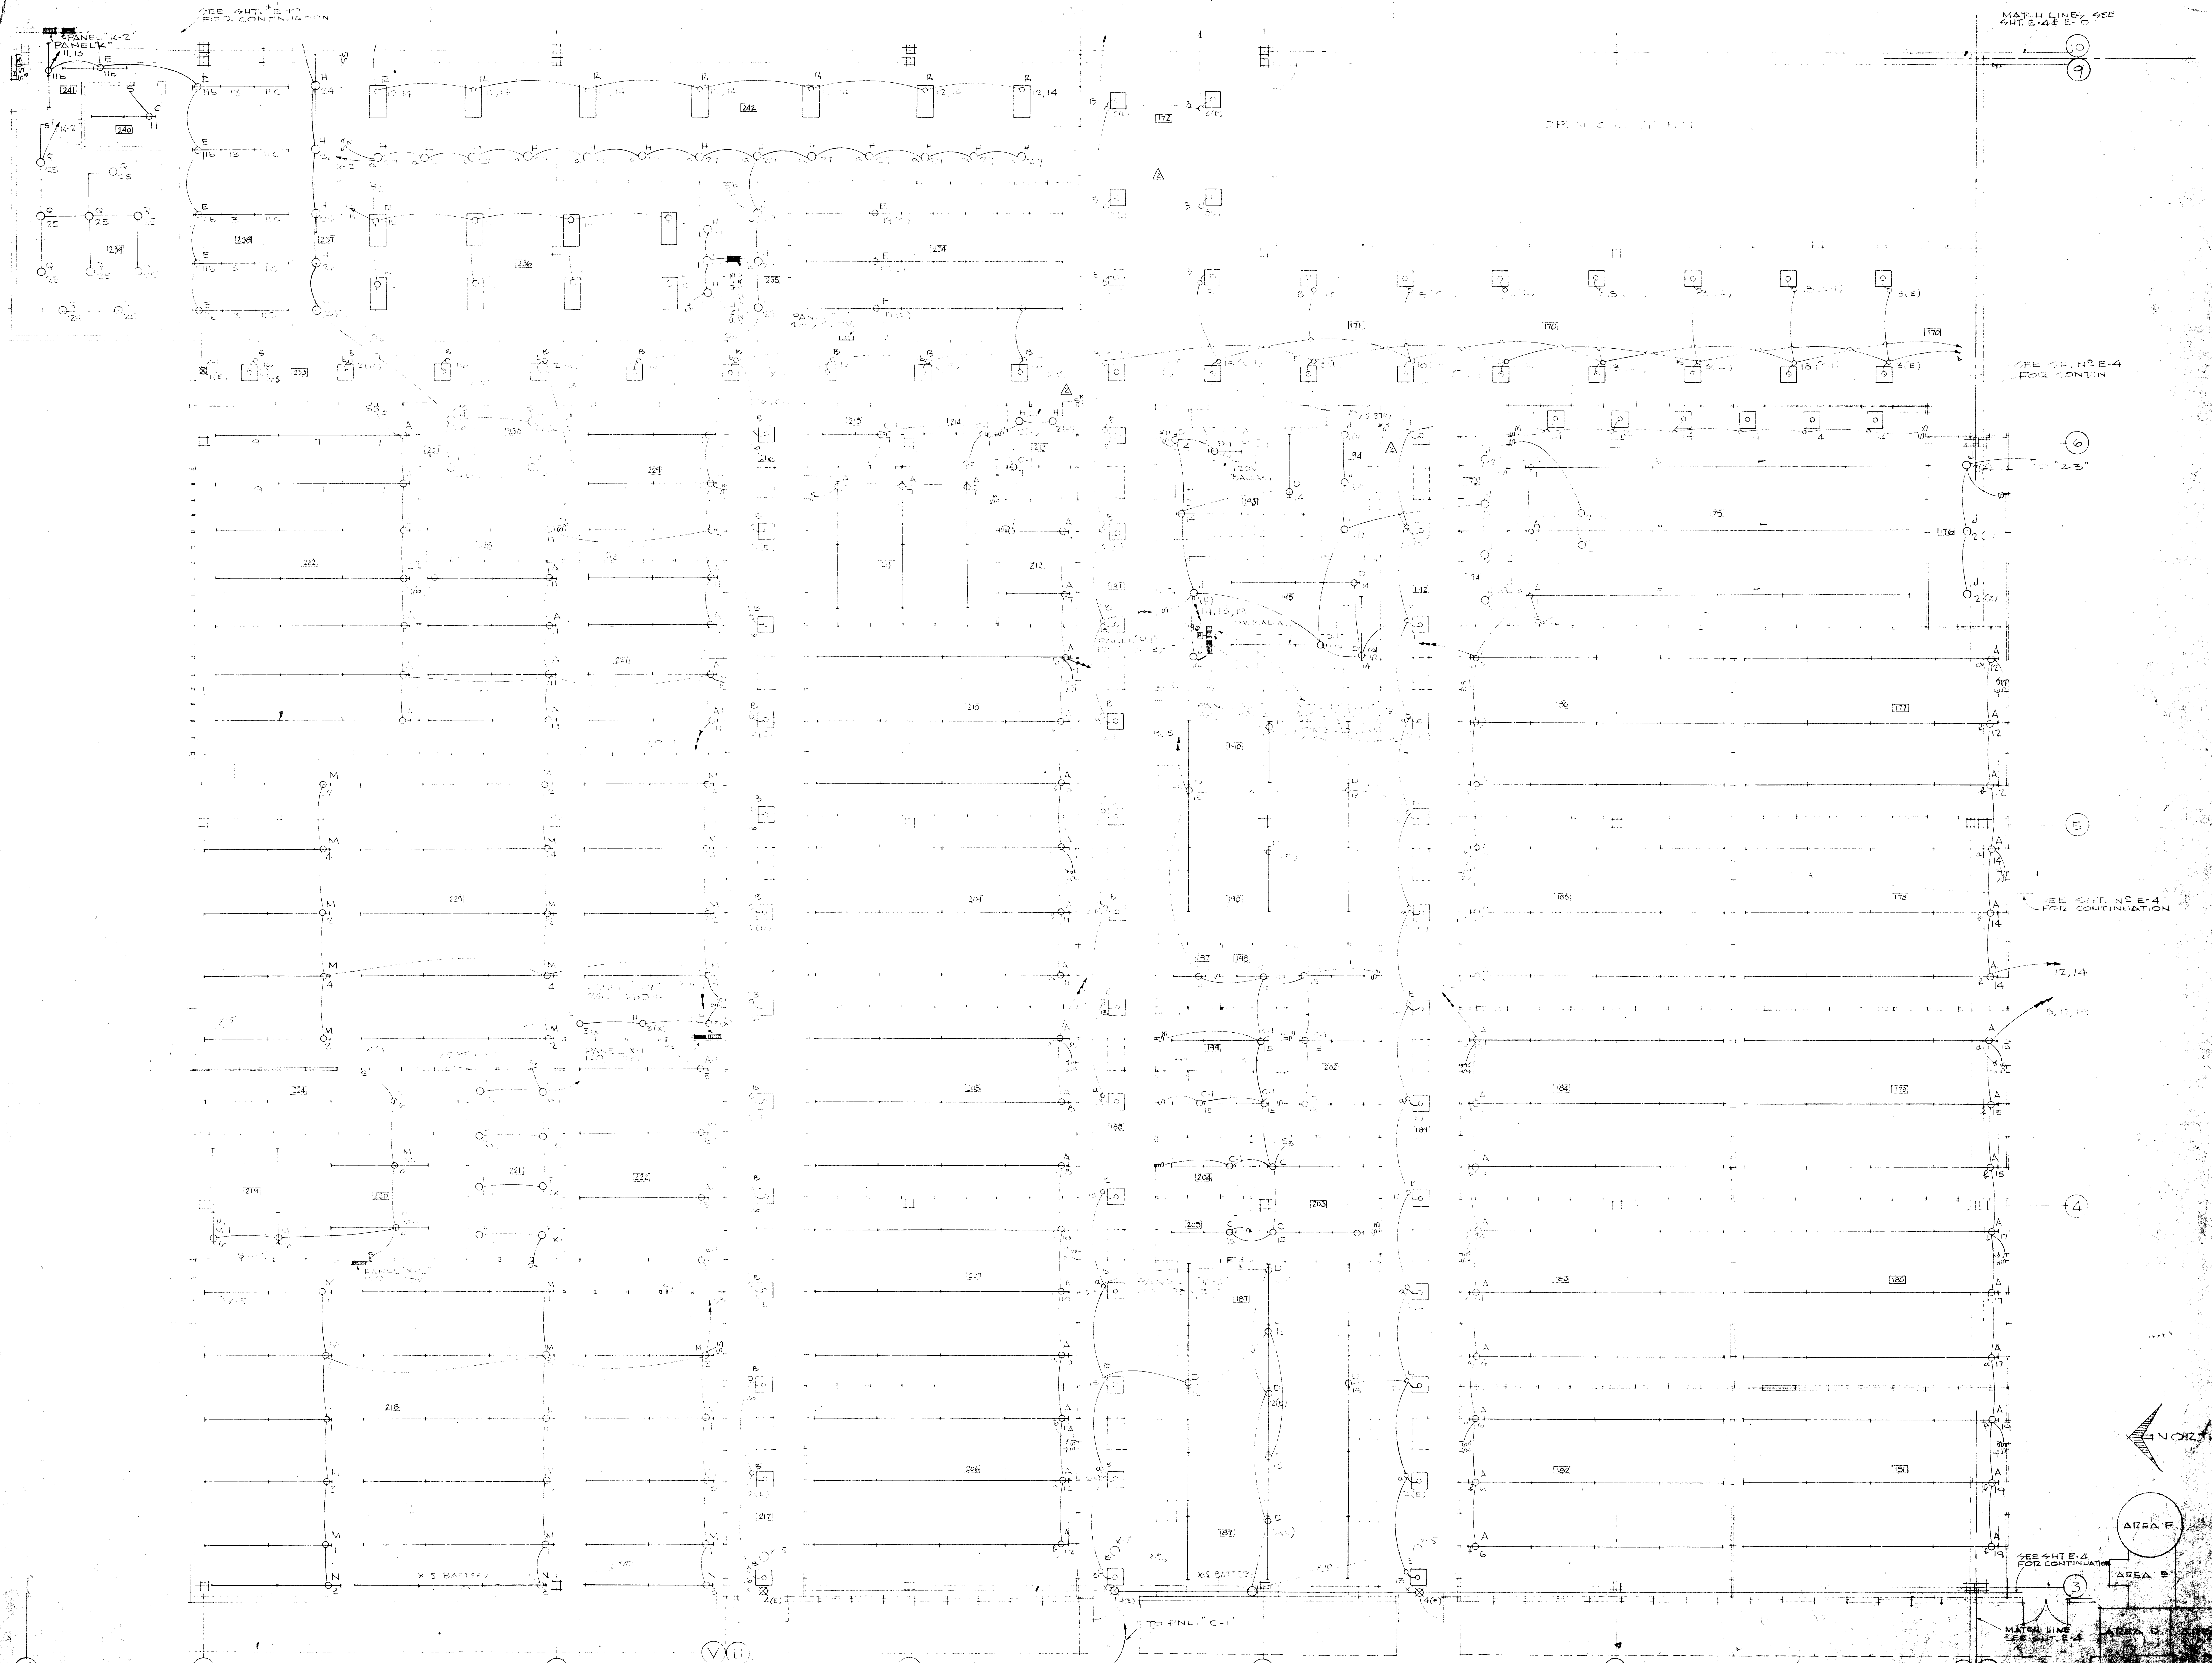


FLOOR PLAN AREA C

943
E-8
OF SHEETS

FLOOR PLAN AREA C

LAWRENCE CENTRAL
SENIOR HIGH SCHOOL
MARION COUNTY, INDIANA


3300 MEADOWS DRIVE
INDIANAPOLIS 6, INDIANA

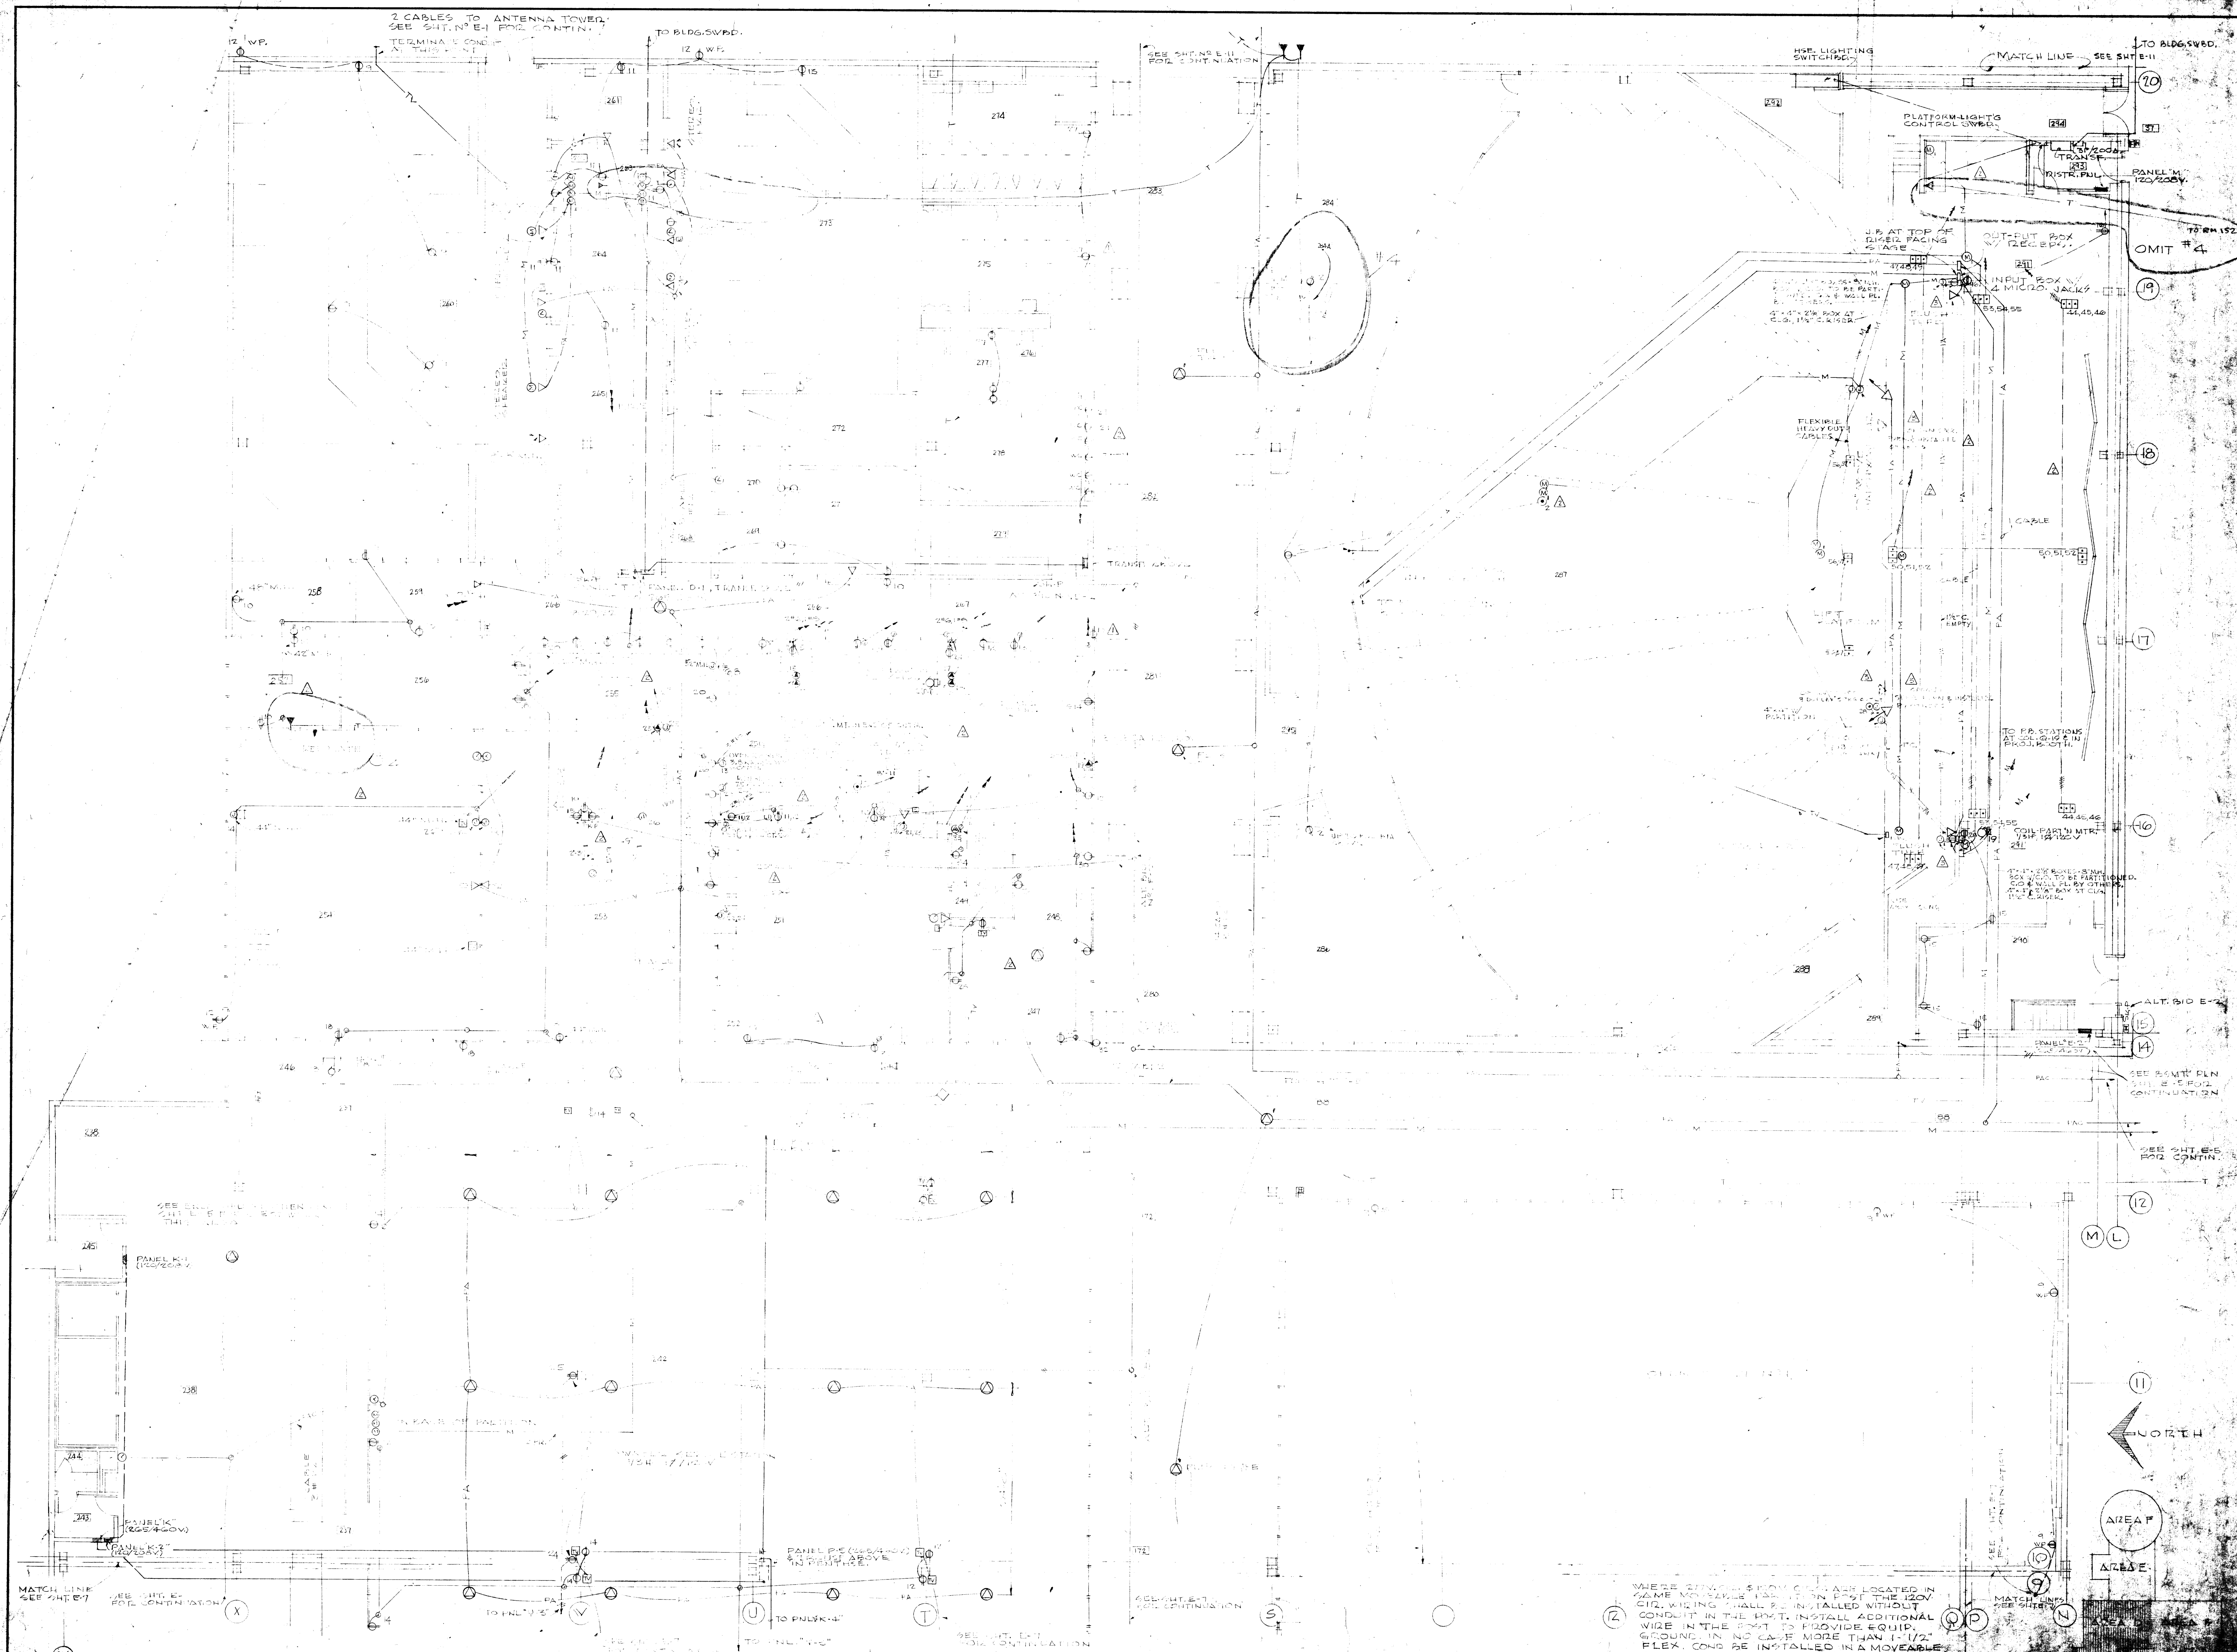

FLOOR PLAN AREA D


WHERE 27" MOVABLE PARALLEL TRACKS ARE LOCATED IN SAME MOVABLE PARALLEL TRACK THE 120V CIRCUIT WIRING SHALL BE INSTALLED WITHOUT CONDUIT IN THE PWT. INSTALL ADDITIONAL WIRE IN THE PWT TO PROVIDE EQUIP. GROUND IN NO CASE MORE THAN 1-1/2" FLEX. COND. BE INSTALLED IN A MOVABLE PARALLEL TRACK.


FILE NO.	2100
DRAWN BY	JHE
DATE	1/2/66
REV.	002
SHEET NUMBER	F-9
OF SHEETS	9
FLOOR PLAN AREA "D"	
LAWRENCE CENTRAL SENIOR HIGH SCHOOL MARION COUNTY, INDIANA	
1989 MEADOWS DRIVE INDIANAPOLIS, INDIANA	

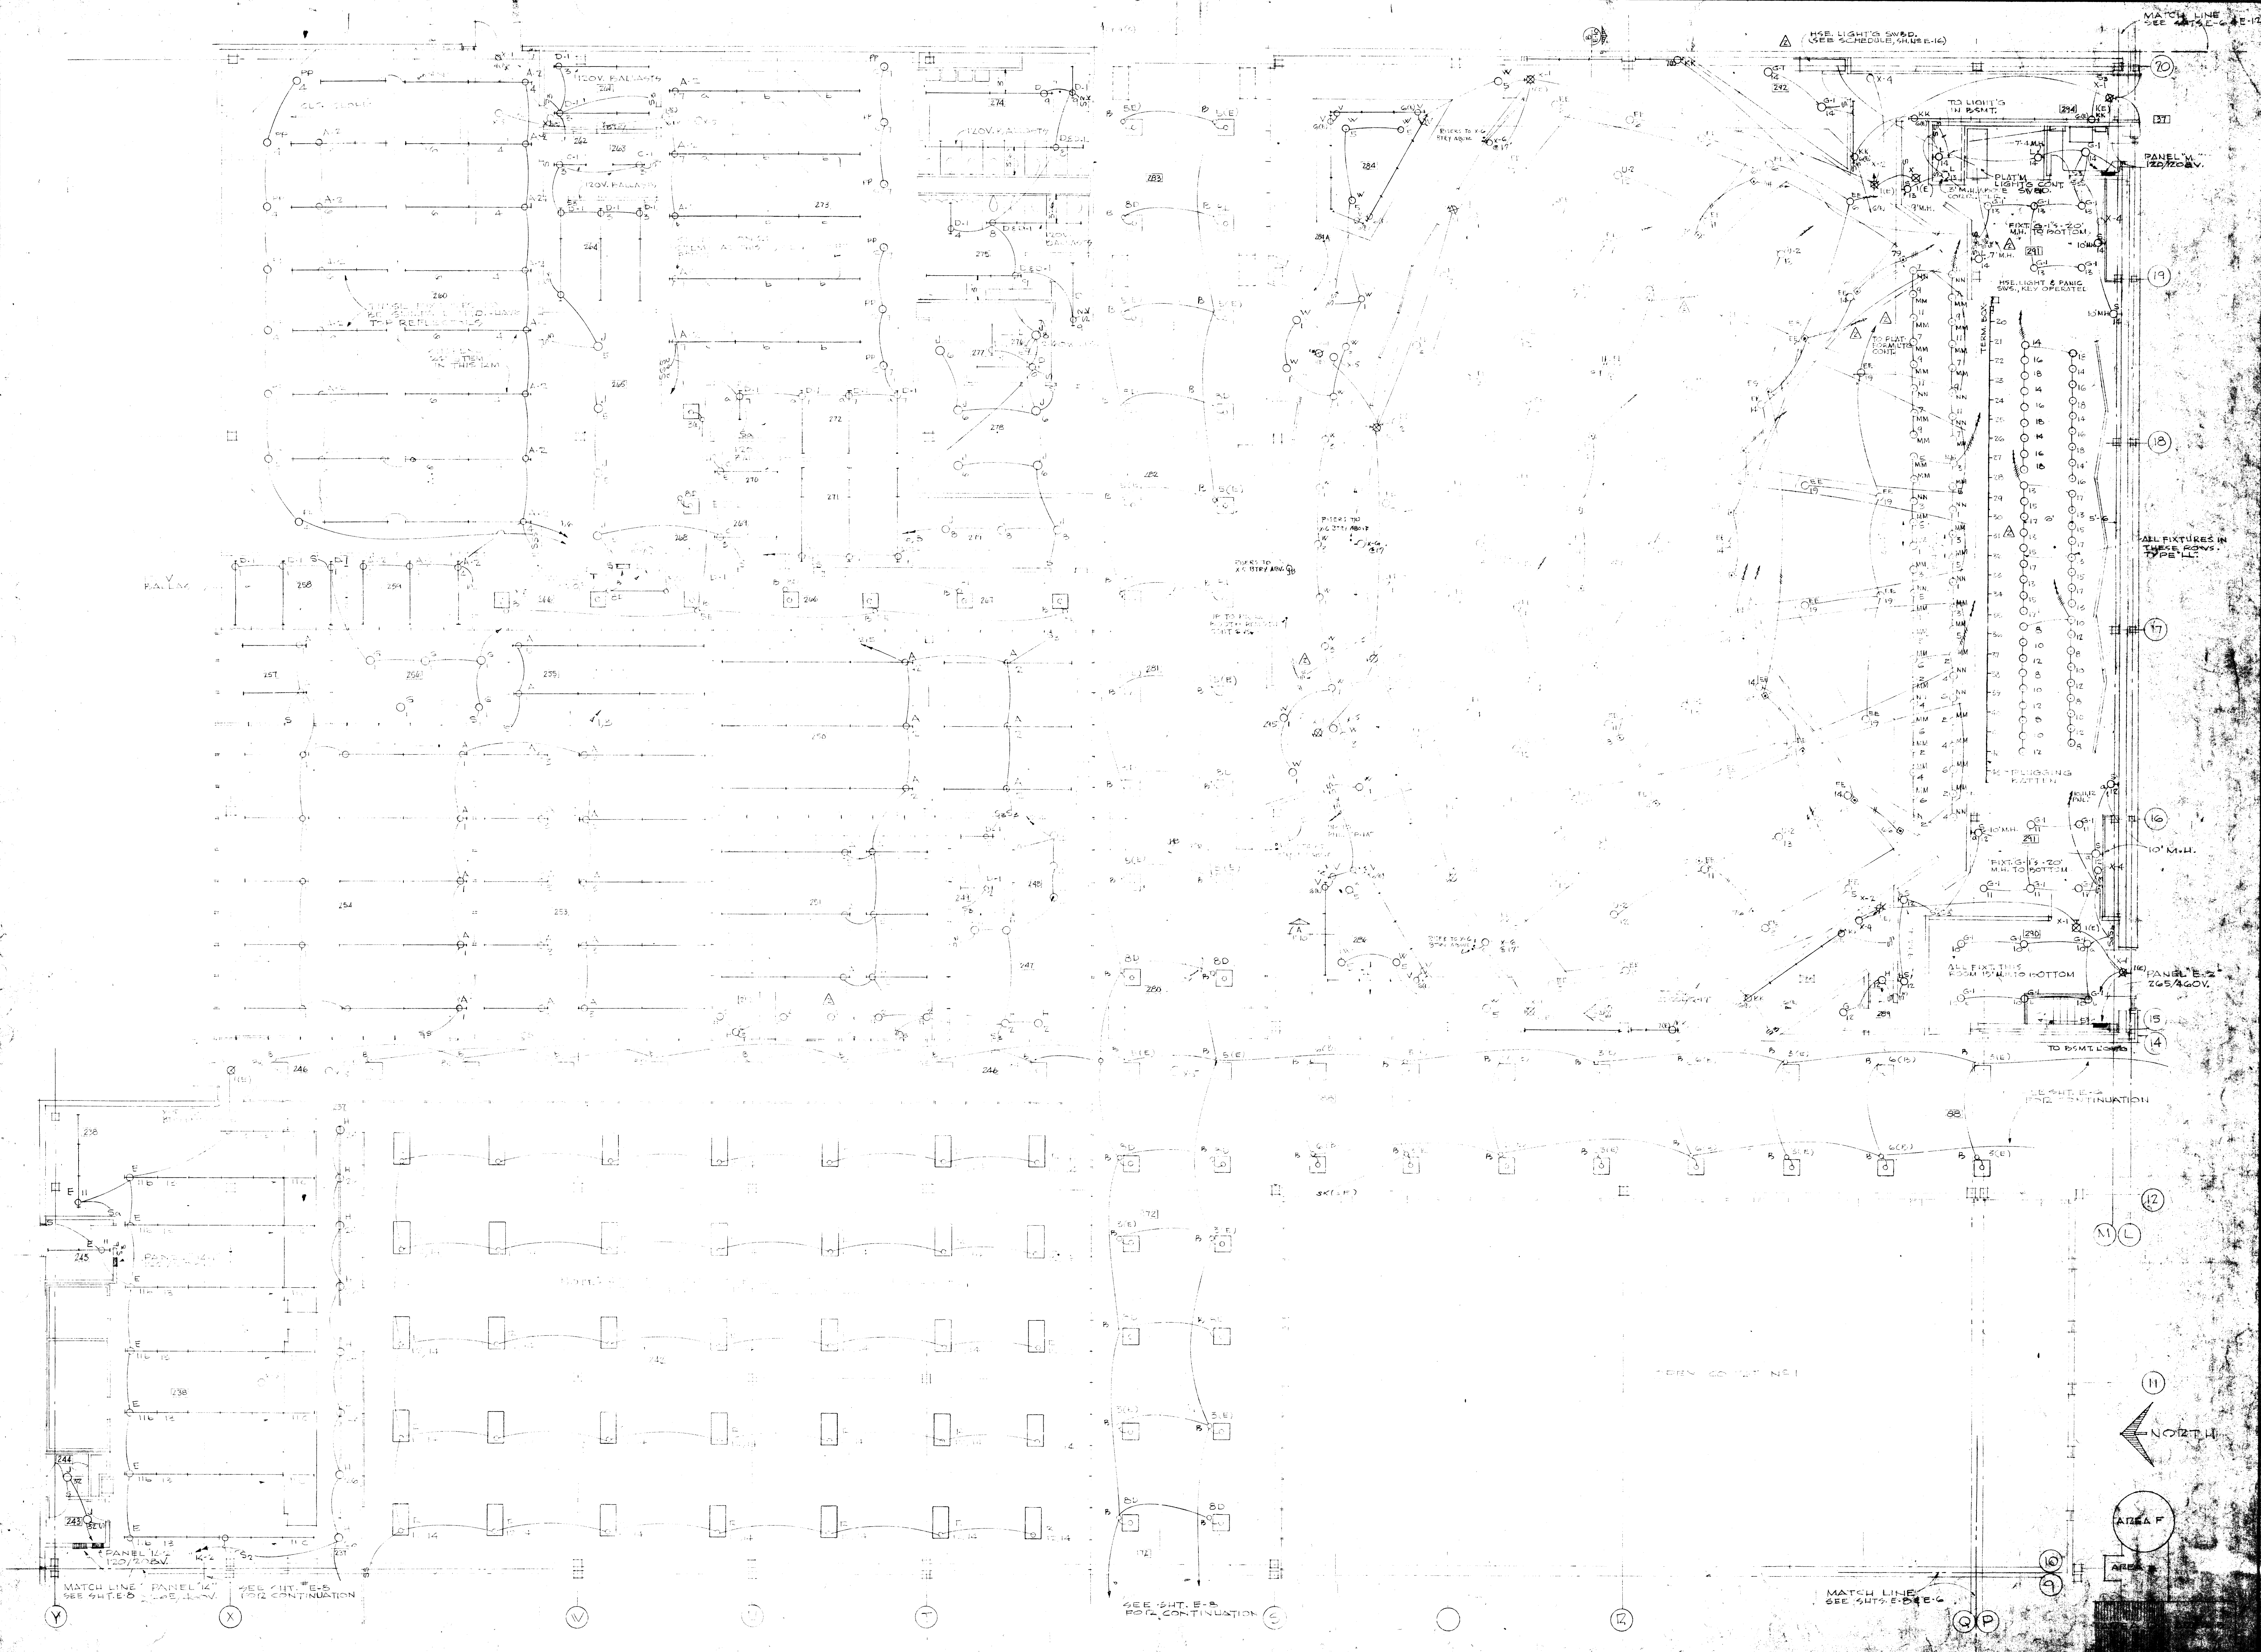

FLOOR PLAN AREA A (D)

PROJECT NUMBER F-10	
SHEETS	
FLOOR PLAN AREA A (D)	
LAWRENCE CENTRAL SENIOR HIGH SCHOOL MARTON COUNTY, INDIANA	
DATE: 11/10/67 BY: J. G. GIBSON CHECKED: J. G. GIBSON	

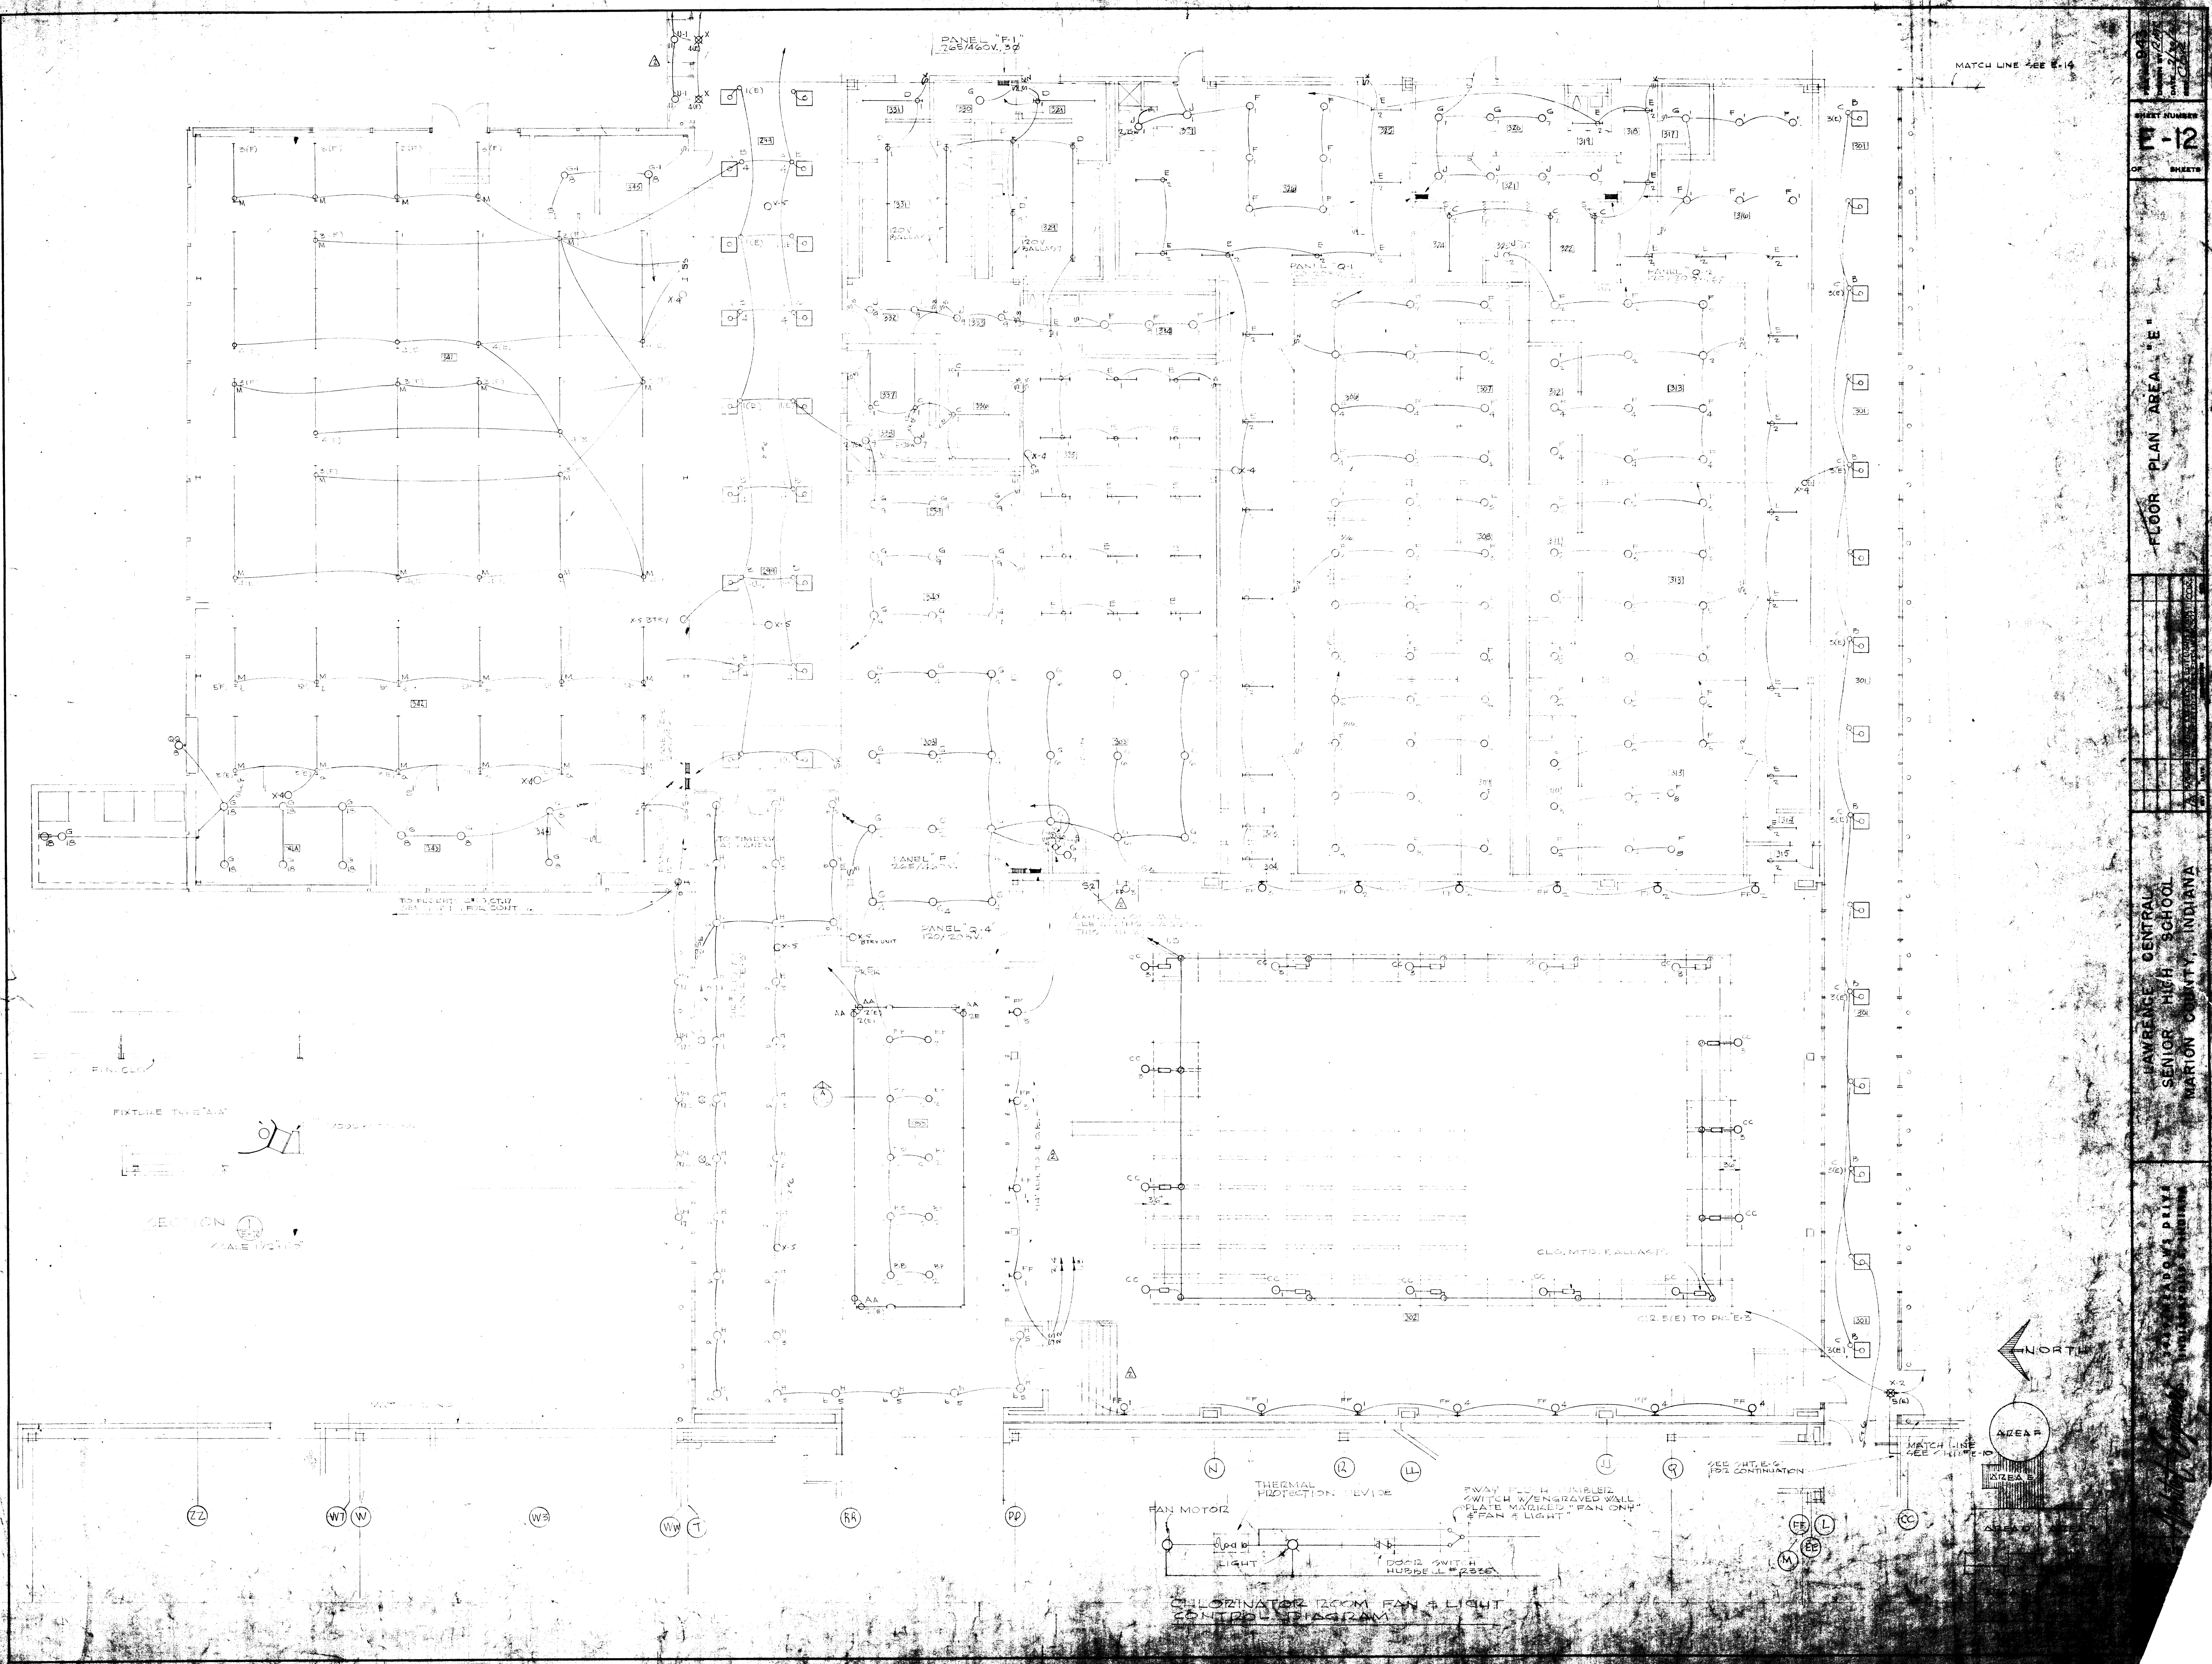

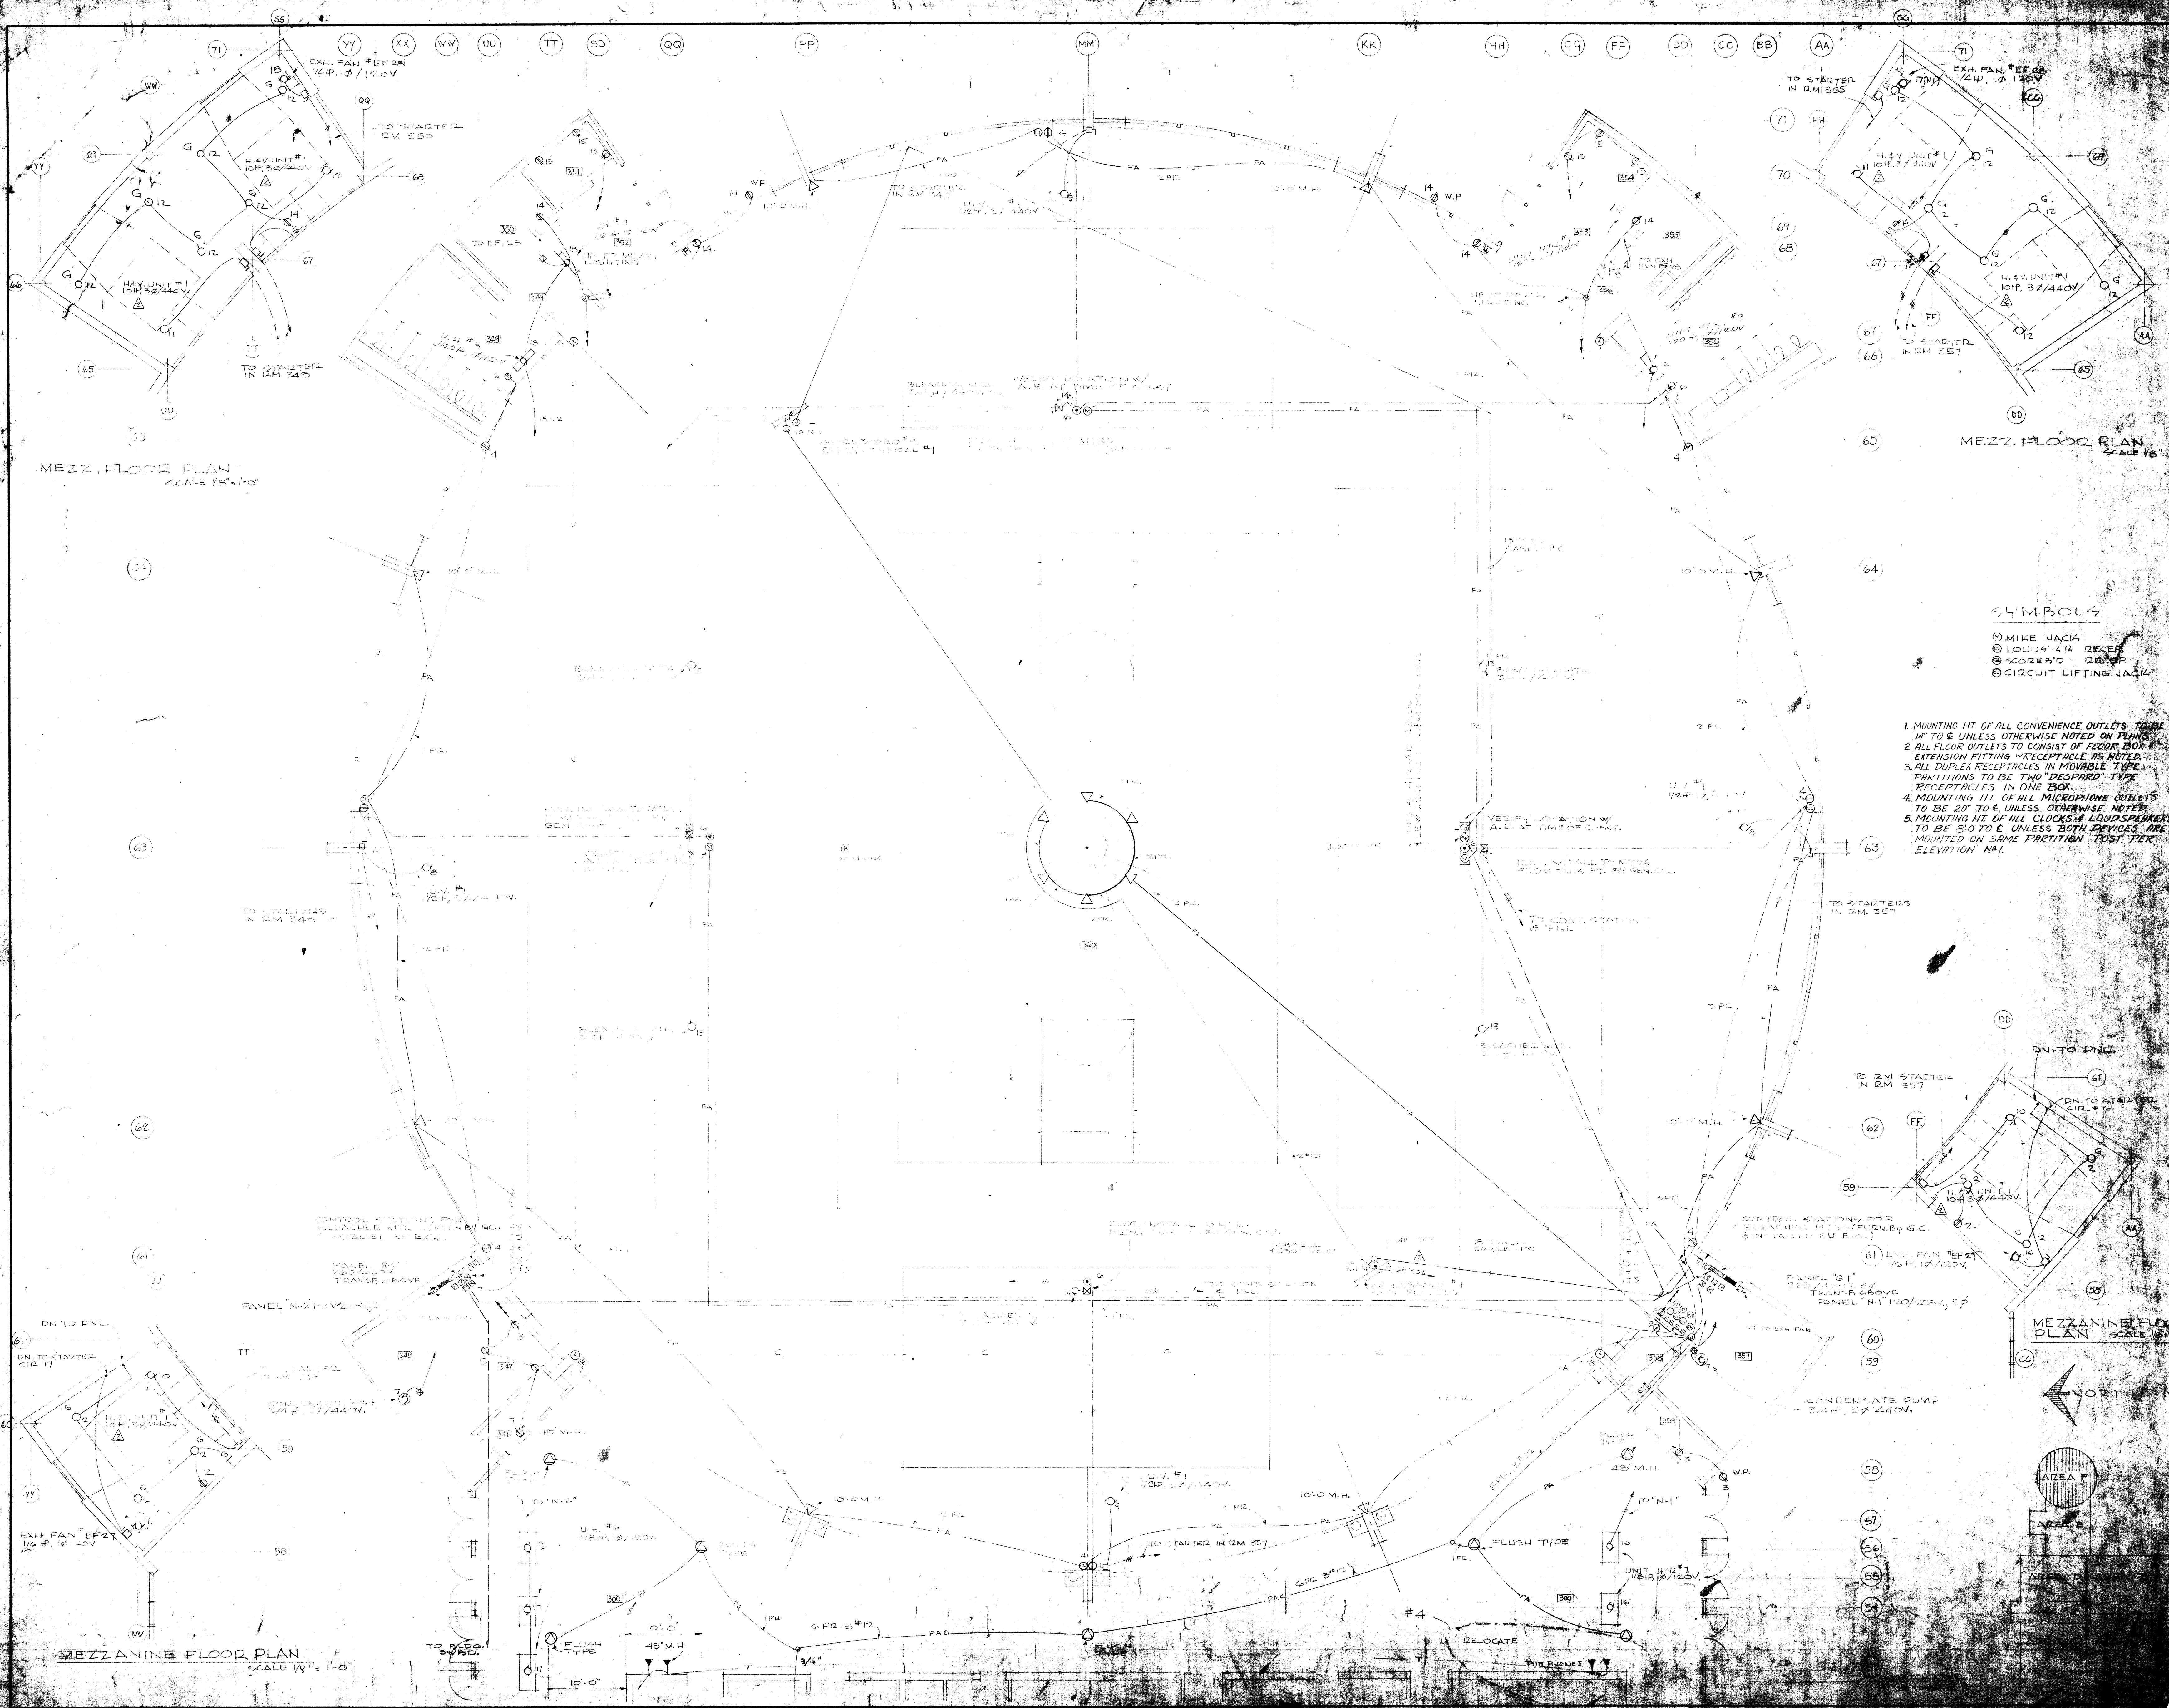

- SYMBOLS**
- ⊙ MIKE JACK
 - ⊙ LOUISIANA RECEPT
 - ⊙ SCORING BOARD
 - ⊙ CIRCUIT LIFTING JACK

1. MOUNTING HT. OF ALL CONVENIENCE OUTLETS TO BE 14" TO 6" UNLESS OTHERWISE NOTED ON PLANS
2. ALL FLOOR OUTLETS TO CONSIST OF REOR BOX EXTENSION FITTING RECEPTACLE AS NOTED
3. ALL DUPLEX RECEPTACLES IN MOVABLE TYPE PARTITIONS TO BE TWO "DESPO" TYPE RECEPTACLES IN ONE BOX
4. MOUNTING HT. OF ALL MICROPHONE OUTLETS TO BE 20" TO 4" UNLESS OTHERWISE NOTED
5. MOUNTING HT. OF ALL CLOCKS & LOUDSPEAKERS TO BE 50" TO 6" UNLESS BOTH DEVICES ARE MOUNTED ON SAME PARTITION POST PER ELEVATION N-1



MEZZ. FLOOR PLAN
 SCALE 1/8" = 1'-0"

MEZZ. FLOOR PLAN
 SCALE 1/8" = 1'-0"

MEZZANINE FLOOR PLAN
 SCALE 1/8" = 1'-0"


MEZZANINE FLOOR PLAN
 SCALE 1/8" = 1'-0"



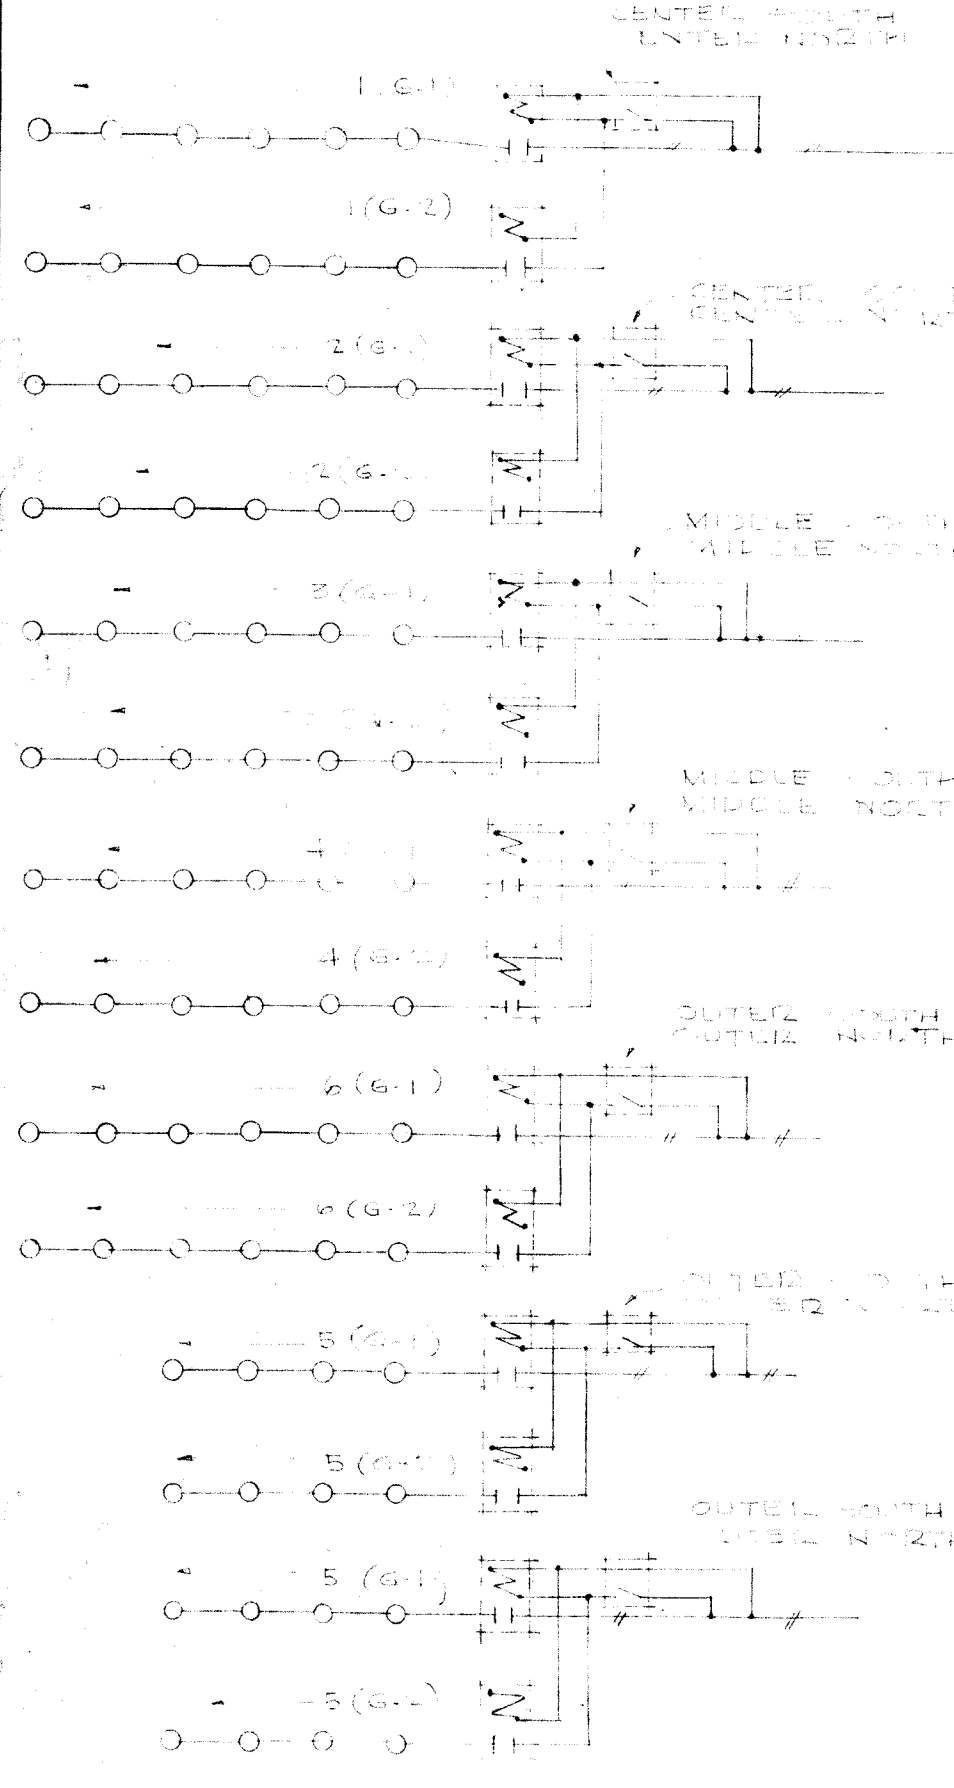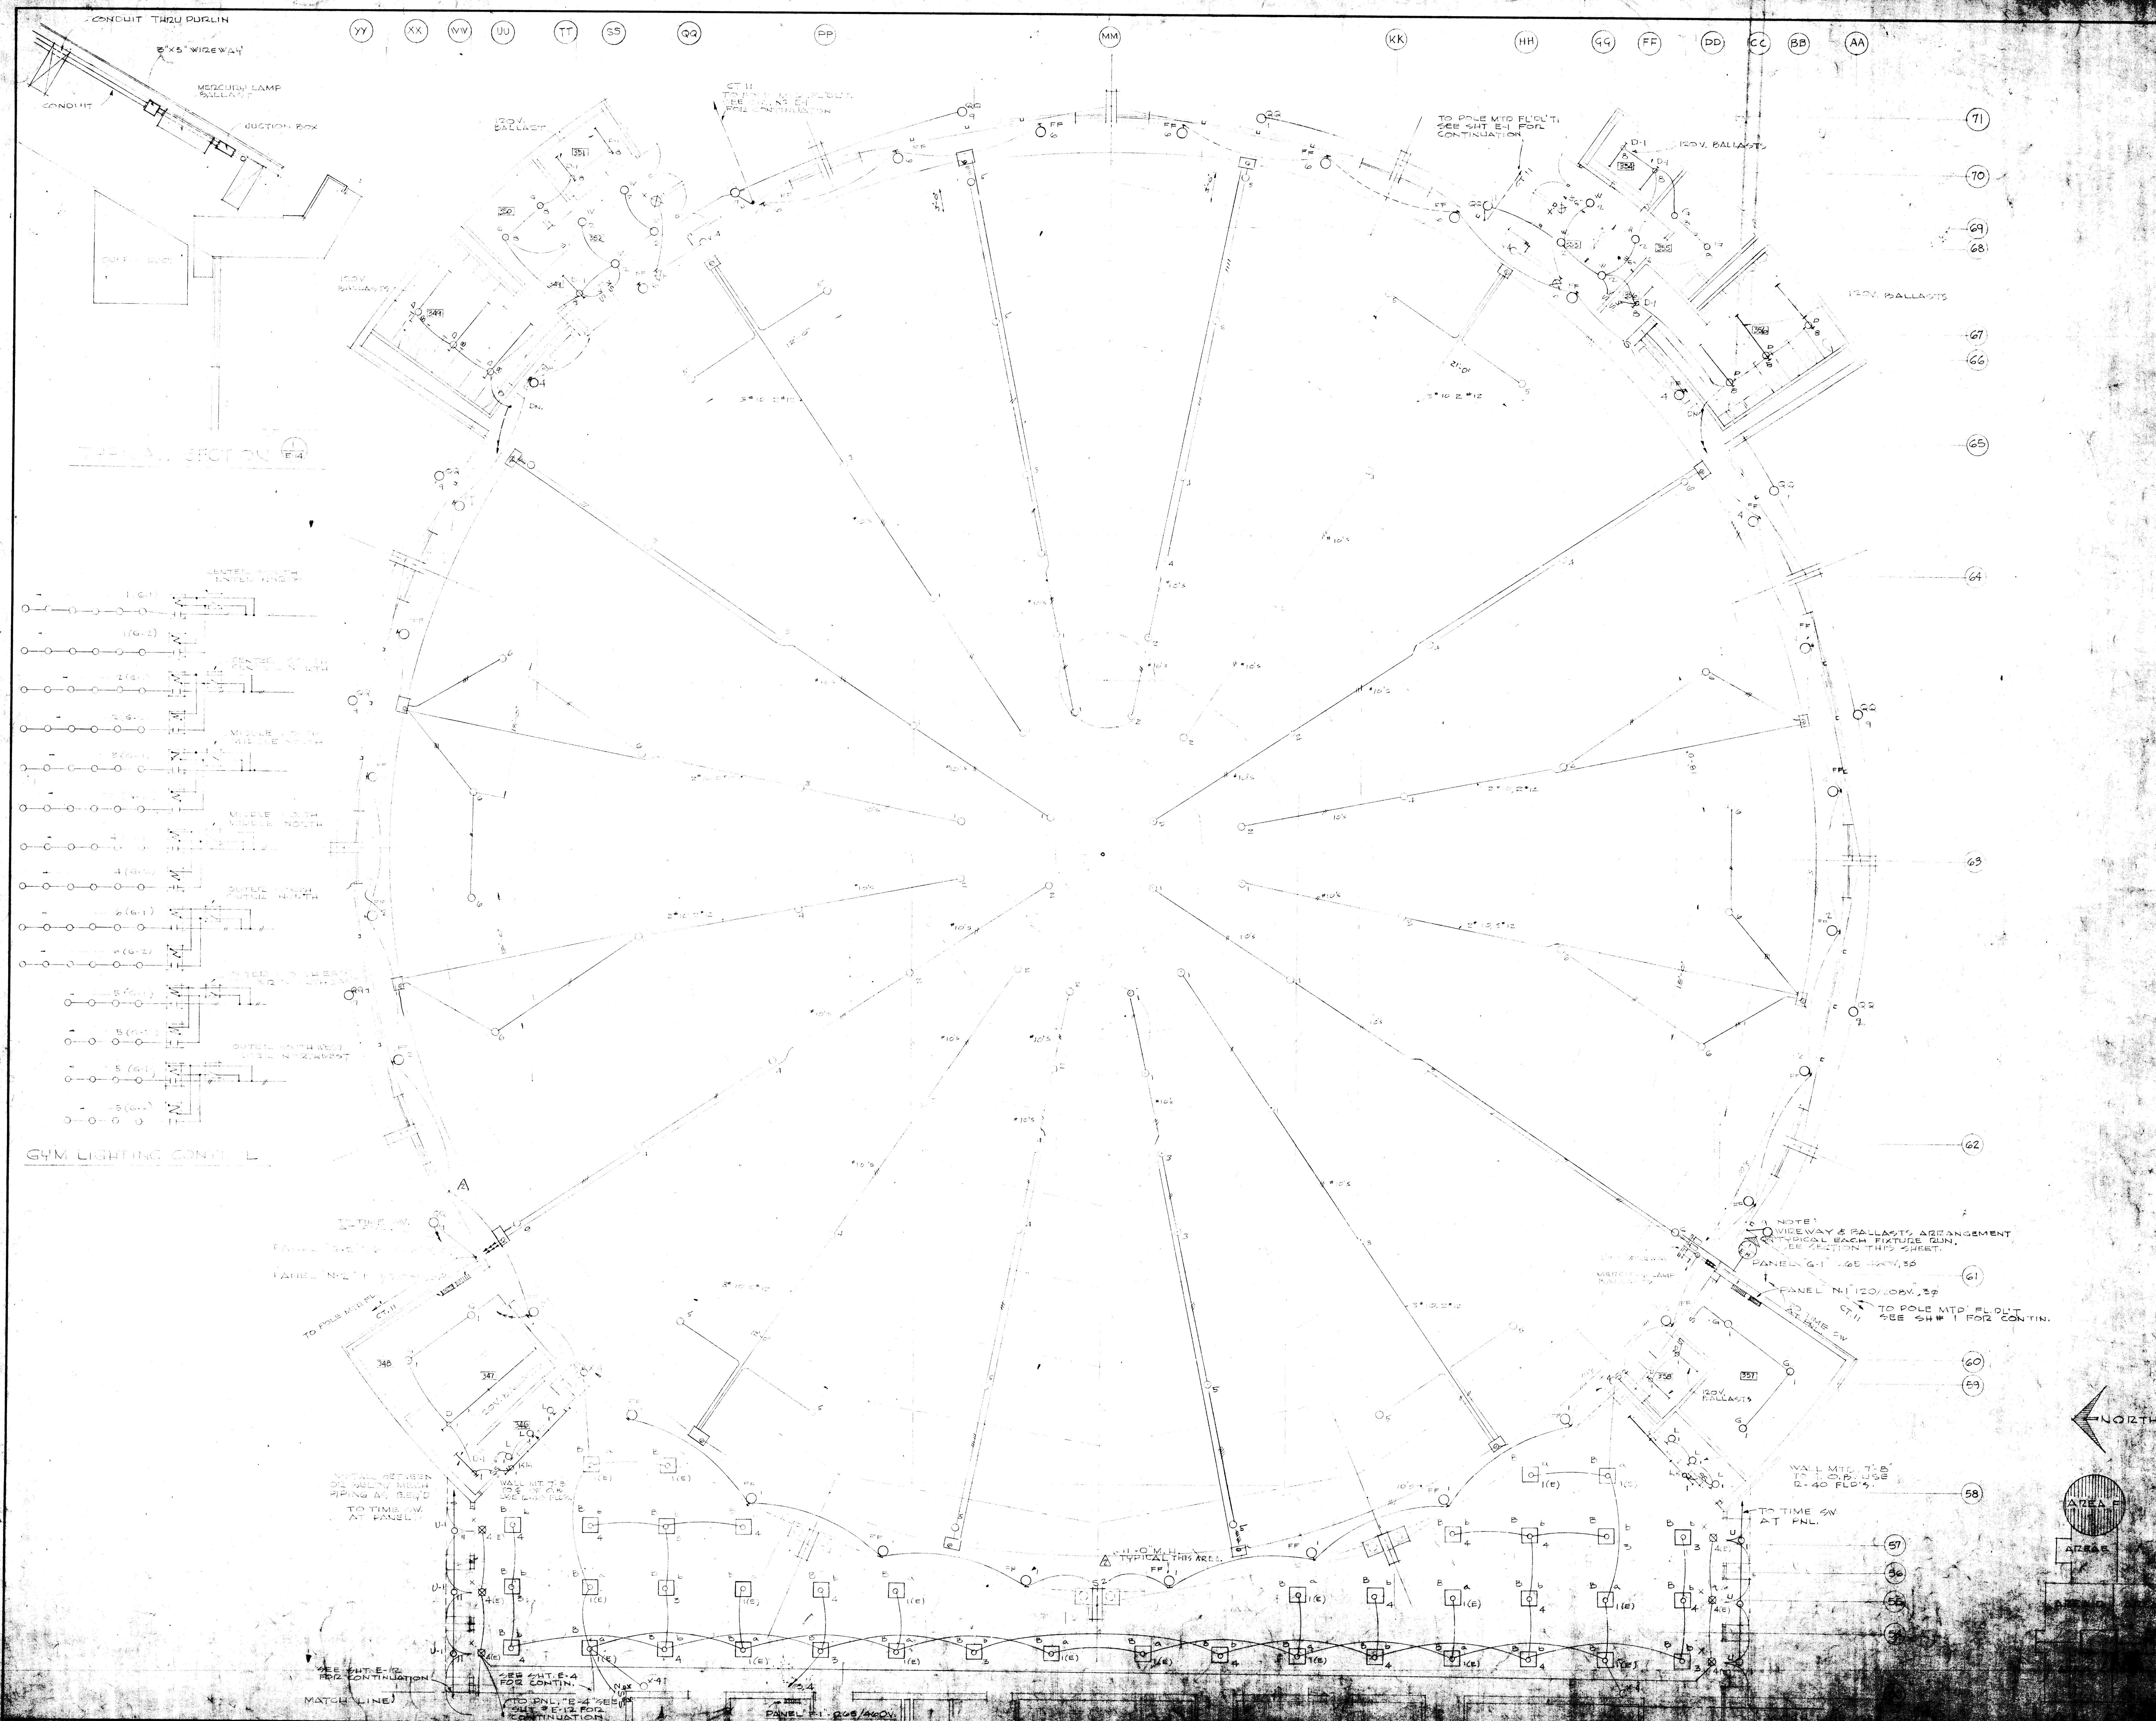

GYM LIGHTING CONDUIT

THESE ARE SECT. ON F-14

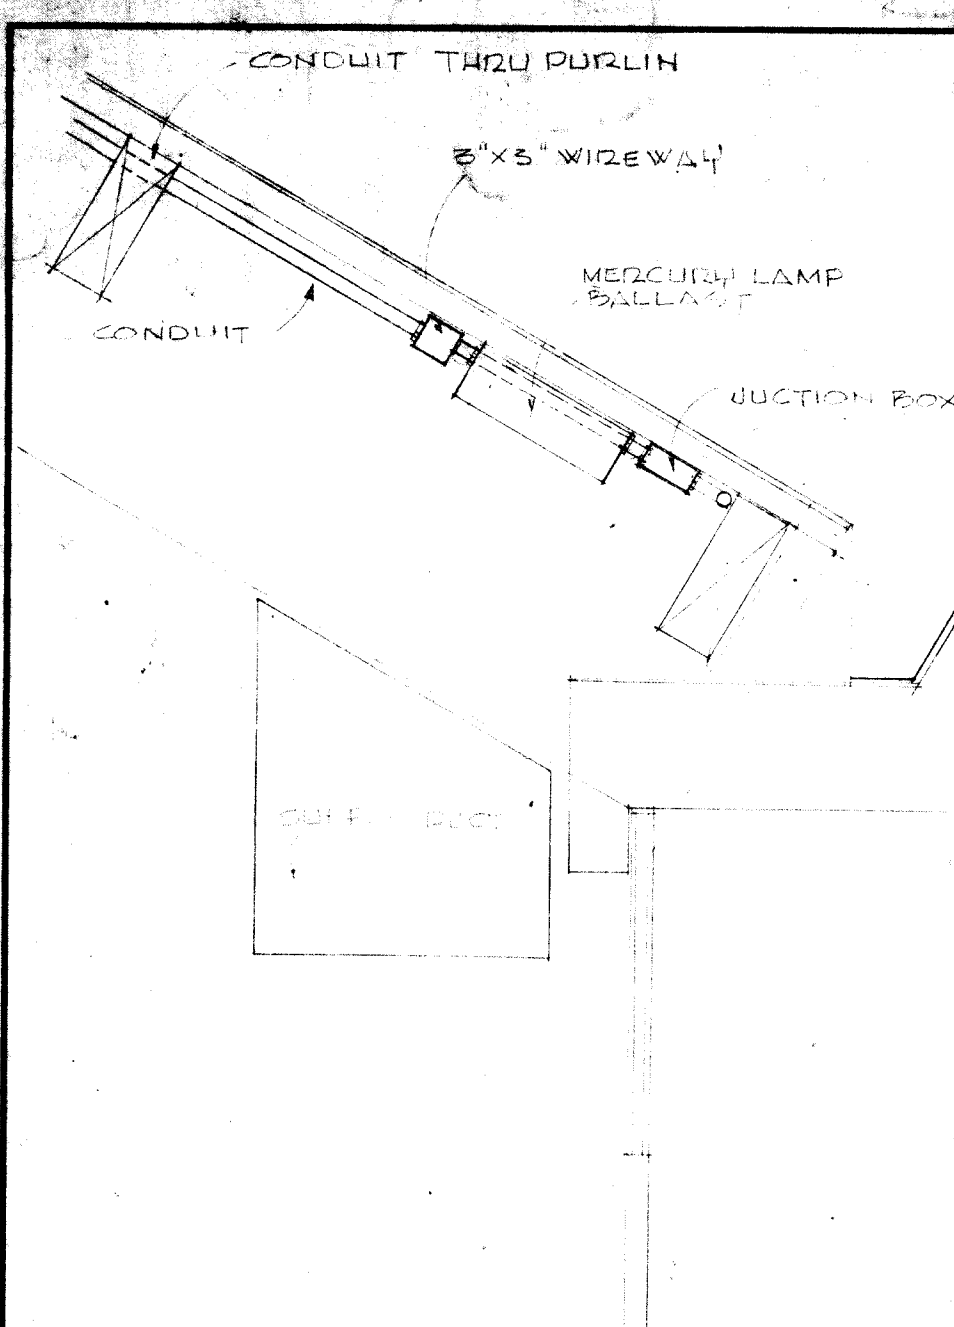

CONDUIT THRU PURLIN

6' x 5' WIDEWAY

MERCURY LAMP BALLAST

CONDUIT

DUCTION BOX

120V. BALLAST

120V. BALLAST


120V. BALLAST

120V. BALLAST

120V. BALLAST

120V. BALLAST

120V. BALLAST

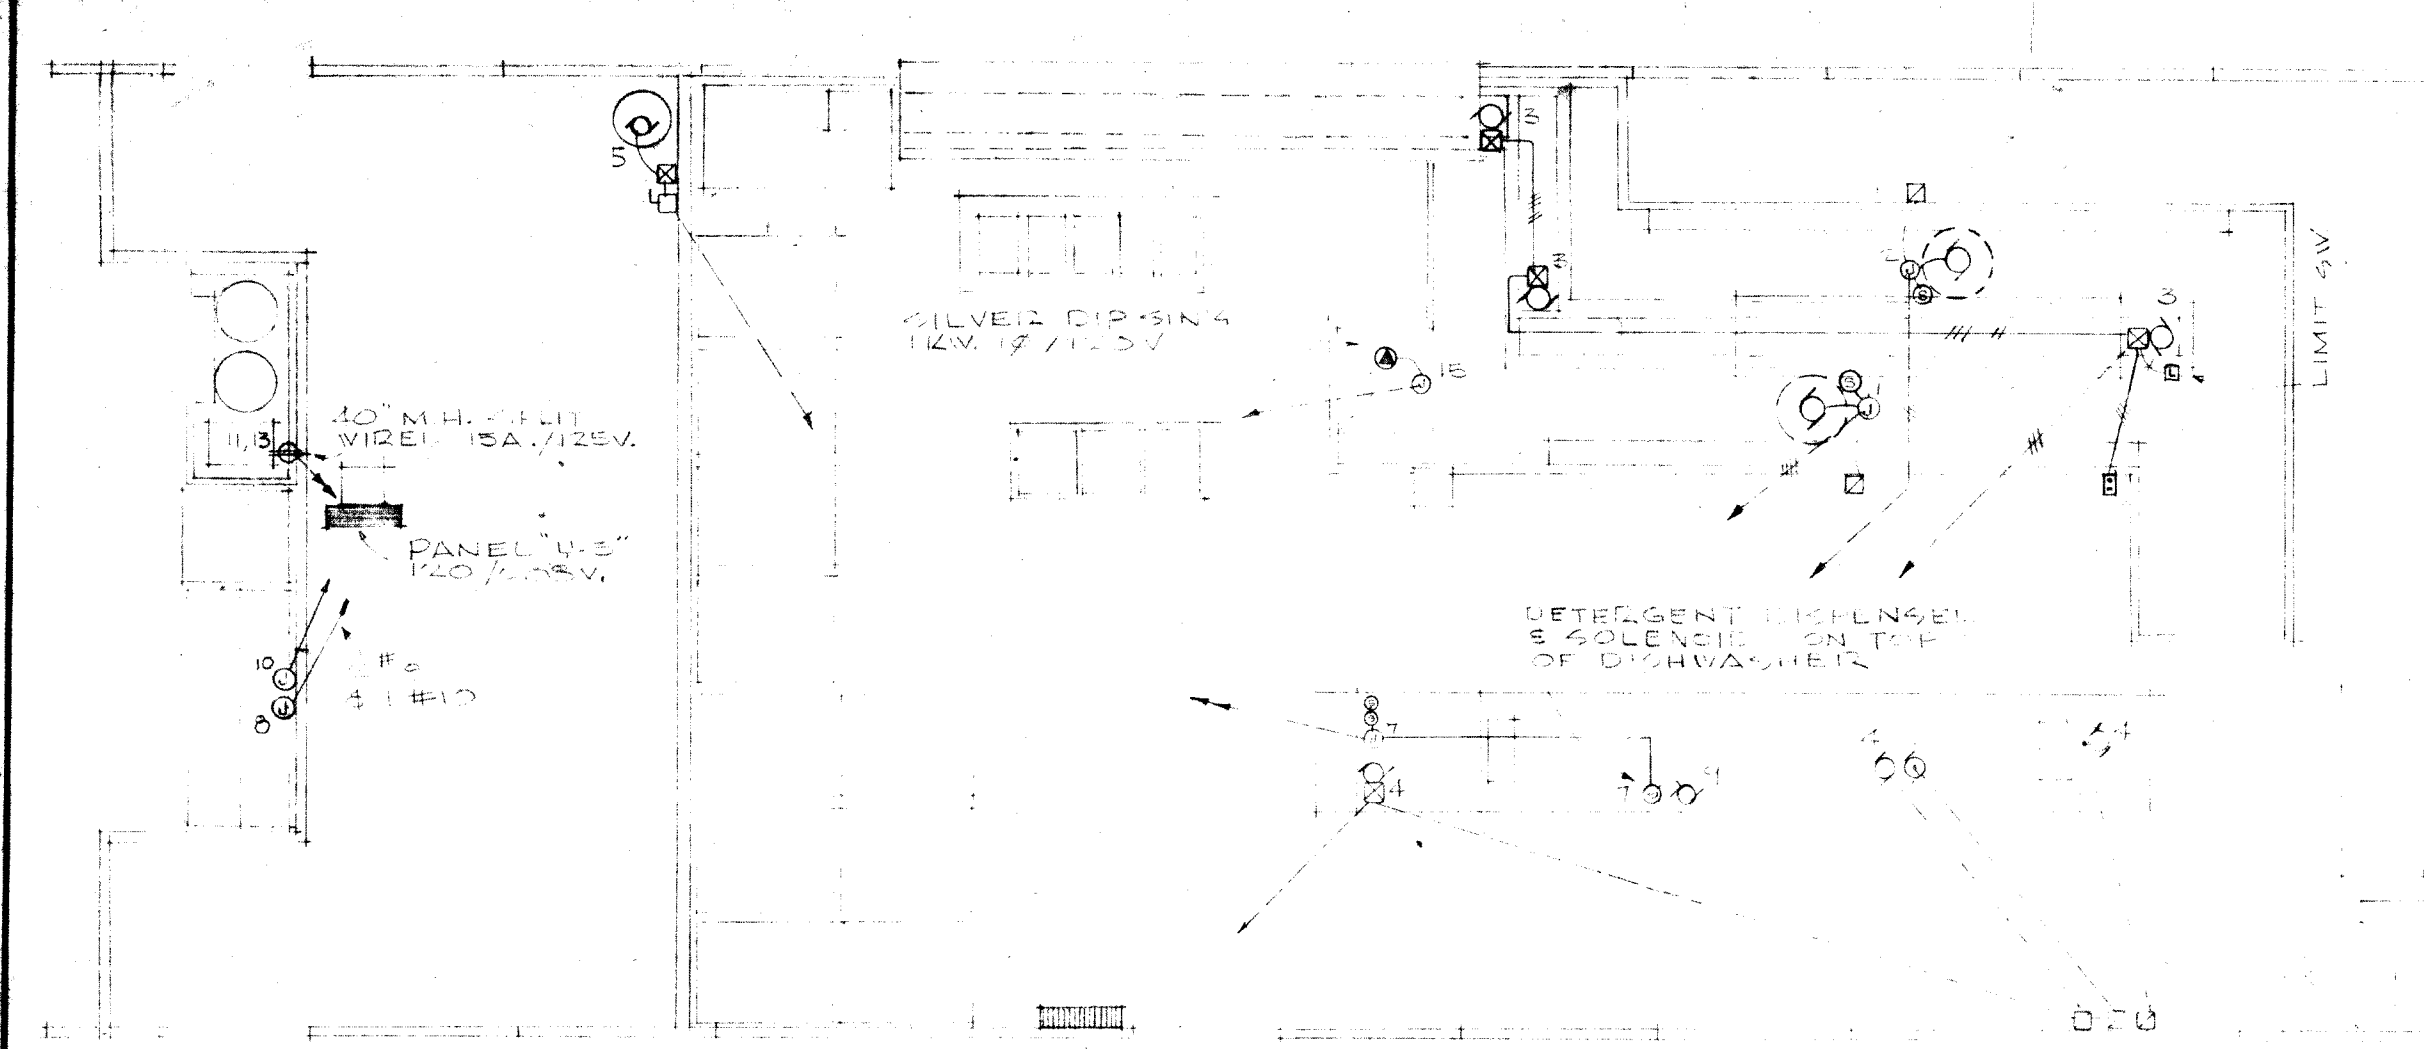


ENLARGED DISHWASHING AREA PLAN
SCALE 1/8" = 1'-0"

CIRCUIT	NO. BOULDER TRIP COIL	WIRE	USE	HP
1	20/50A	2#12	GAS DISPOSER	1/2 HP
2	20/50A	2#12	OVEN	3/4 HP
3	20/50A	2#12	OVEN	3/4 HP
4	20/50A	2#12	OVEN	3/4 HP
5	20/50A	2#12	OVEN	3/4 HP
6	20/50A	2#12	OVEN	3/4 HP
7	20/50A	2#12	OVEN	3/4 HP
8	20/50A	2#12	OVEN	3/4 HP
9	20/50A	2#12	OVEN	3/4 HP
10	20/50A	2#12	OVEN	3/4 HP
11-16	20/50A	2#12	LIGHTING	120W




CIRCUIT	NO. BOULDER TRIP COIL	WIRE	USE	HP
1	20/50A	2#12	GAS DISPOSER	1/2 HP
2	20/50A	2#12	OVEN	3/4 HP
3	20/50A	2#12	OVEN	3/4 HP
4	20/50A	2#12	OVEN	3/4 HP
5	20/50A	2#12	OVEN	3/4 HP
6	20/50A	2#12	OVEN	3/4 HP
7	20/50A	2#12	OVEN	3/4 HP
8	20/50A	2#12	OVEN	3/4 HP
9	20/50A	2#12	OVEN	3/4 HP
10	20/50A	2#12	OVEN	3/4 HP
11-16	20/50A	2#12	LIGHTING	120W

CIRCUIT	NO. BOULDER TRIP COIL	WIRE	USE	HP
1	20/50A	2#12	GAS DISPOSER	1/2 HP
2	20/50A	2#12	OVEN	3/4 HP
3	20/50A	2#12	OVEN	3/4 HP
4	20/50A	2#12	OVEN	3/4 HP
5	20/50A	2#12	OVEN	3/4 HP
6	20/50A	2#12	OVEN	3/4 HP
7	20/50A	2#12	OVEN	3/4 HP
8	20/50A	2#12	OVEN	3/4 HP
9	20/50A	2#12	OVEN	3/4 HP
10	20/50A	2#12	OVEN	3/4 HP
11-16	20/50A	2#12	LIGHTING	120W

CIRCUIT	NO. BOULDER TRIP COIL	WIRE	USE	HP
1	20/50A	2#12	GAS DISPOSER	1/2 HP
2	20/50A	2#12	OVEN	3/4 HP
3	20/50A	2#12	OVEN	3/4 HP
4	20/50A	2#12	OVEN	3/4 HP
5	20/50A	2#12	OVEN	3/4 HP
6	20/50A	2#12	OVEN	3/4 HP
7	20/50A	2#12	OVEN	3/4 HP
8	20/50A	2#12	OVEN	3/4 HP
9	20/50A	2#12	OVEN	3/4 HP
10	20/50A	2#12	OVEN	3/4 HP
11-16	20/50A	2#12	LIGHTING	120W

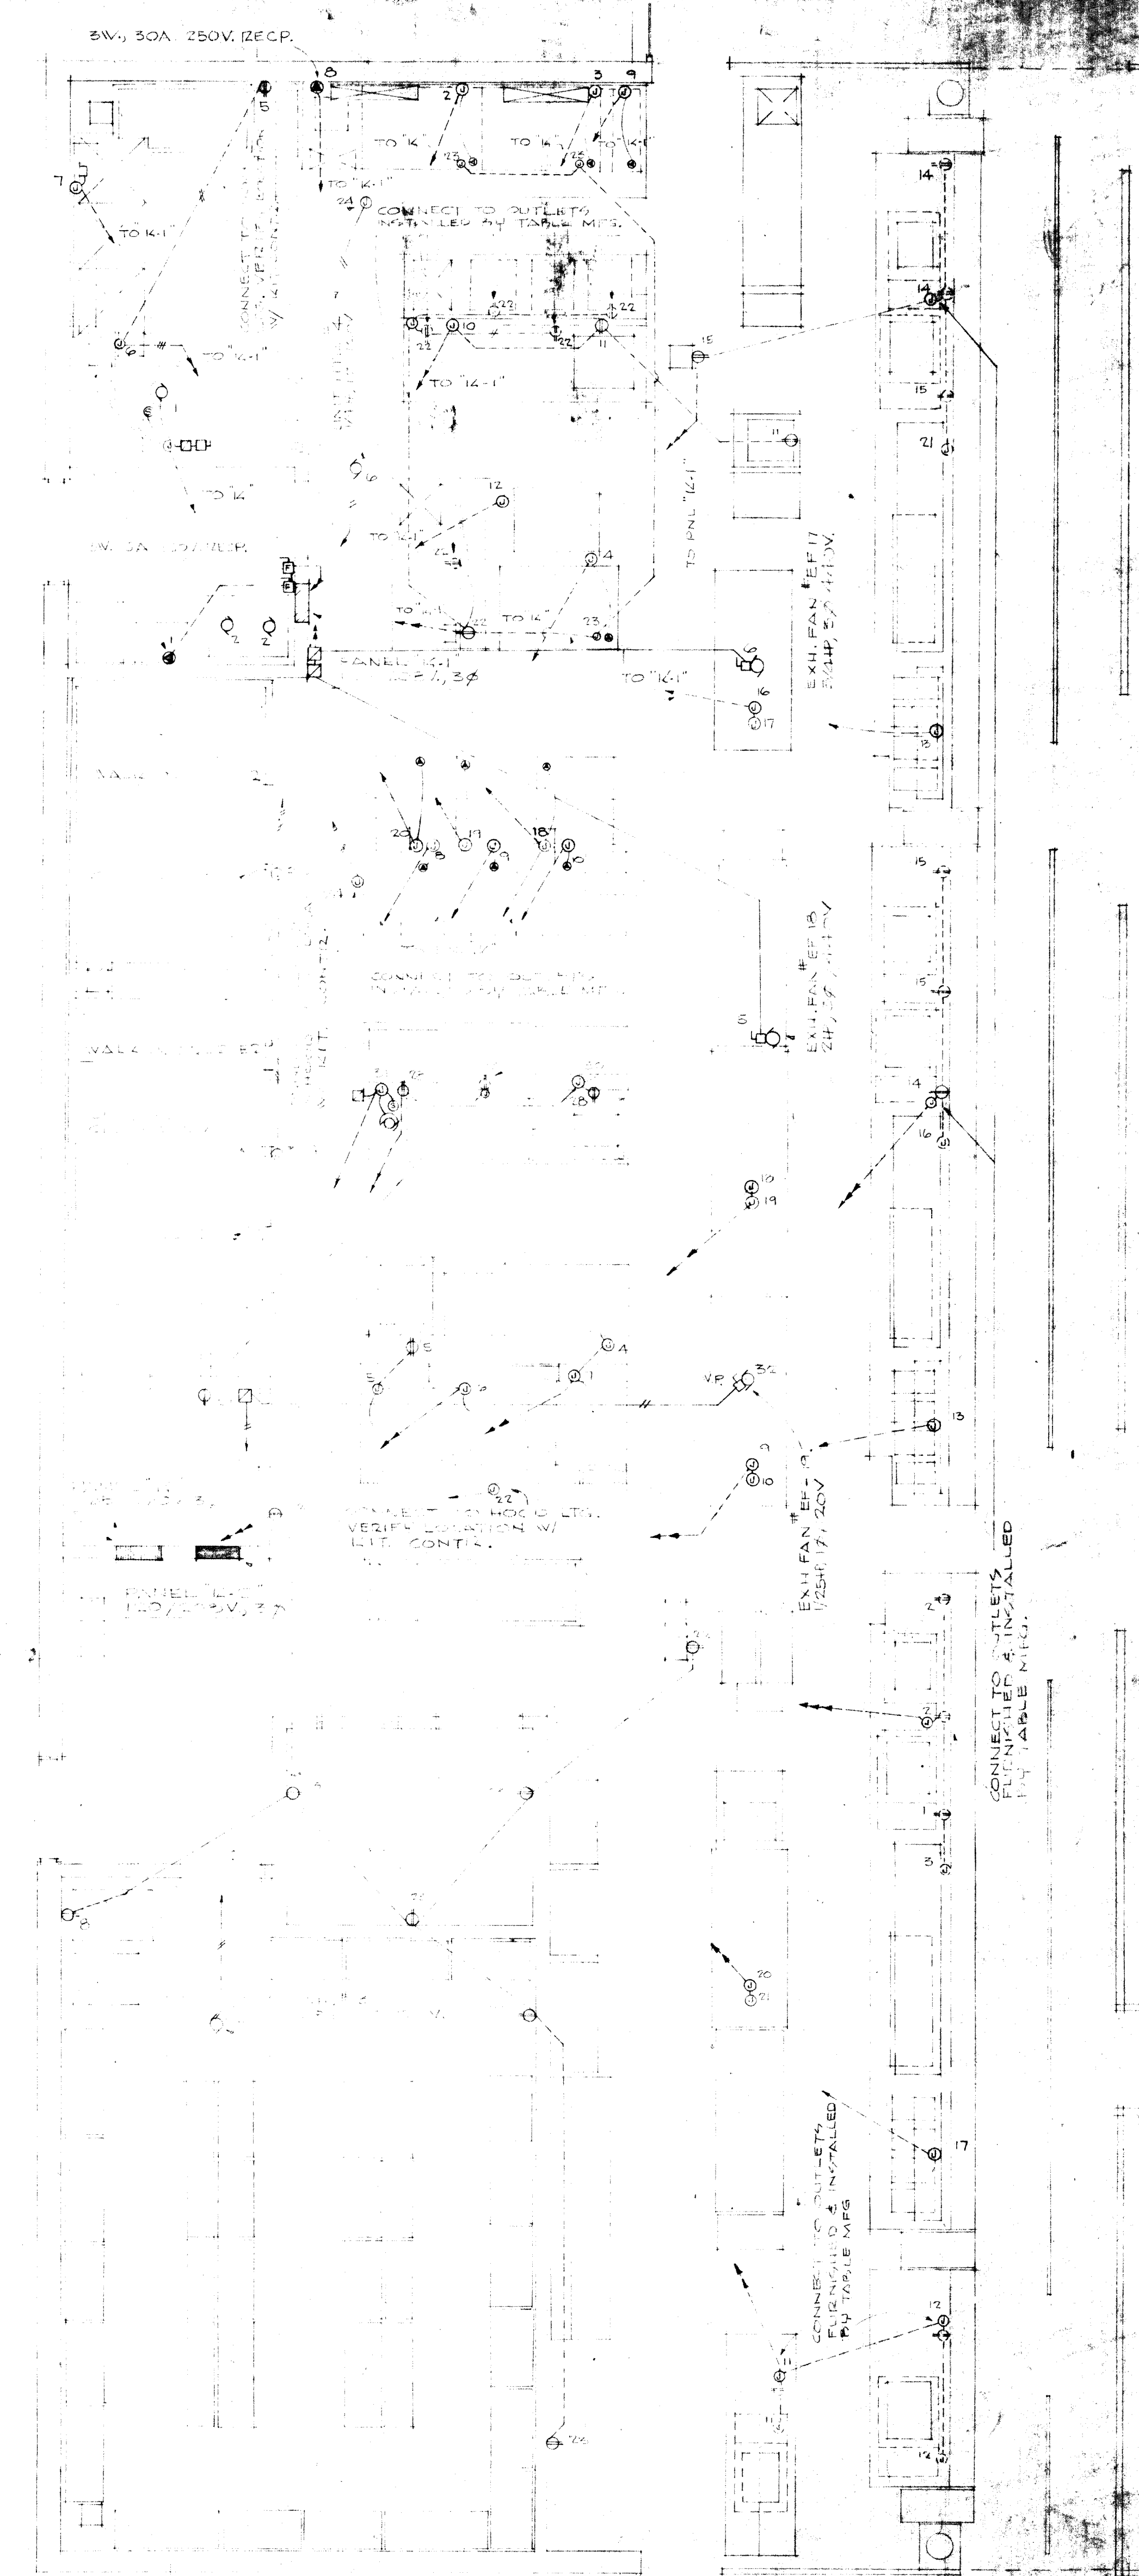


  ENLARGED KITCHEN PLAN
SCALE 1/8" = 1'-0"

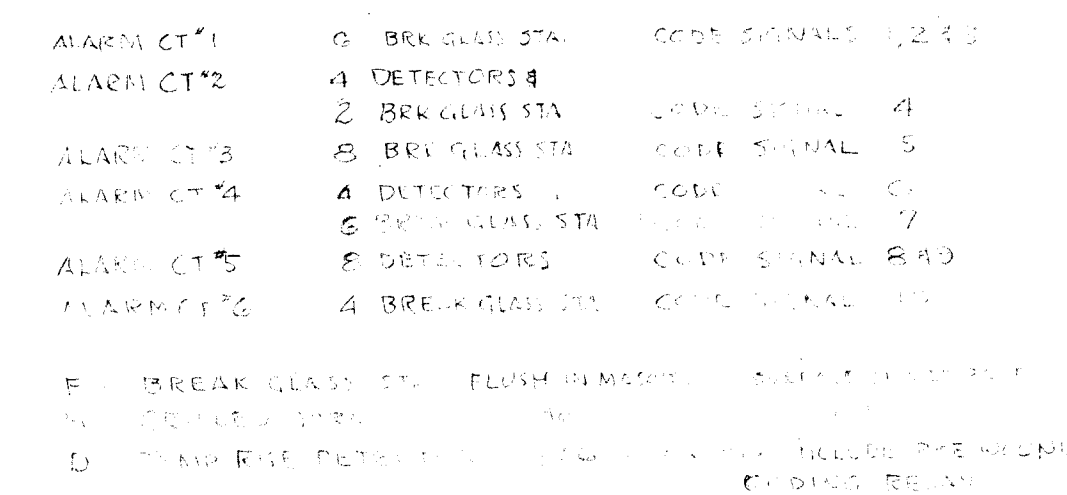[illegible]

NOTES: DISCONNECT 24V. TO MOTOR MAY BE
TRIMMER 24V. IN CONTROL CIRCUIT.

CIRCUIT SELECTOR & DIMMER CONTROL BOARD SCHEDULE					
ITEM CONTROLLED	TOTAL WATTAGE	NO OF CIRCUITS	CT. NO	C/S TRIP CAL. IN	CONTROL
FRONT PLATFORM DOWNLIGHTS	900 W	1	1	20A	1
	900 W	1	2	20A	1
	900 W	1	3	20A	1
	1800 W	2	2, 7	20A	1
	1800 W	2	4, 9	20A	1
	1800 W	2	6, 11	20A	1
REAR PLATFORM DOWNLIGHTS	900 W	1	13	20A	1
	900 W	1	15	20A	1
	900 W	1	17	20A	1
	1800 W	2	8, 14	20A	1
	1800 W	2	10, 16	20A	1
	1800 W	2	12, 18	20A	1
ALL DIMMERS IN ABOVE SECTION TO HAVE 600W RATING (w) CONTROL CONVENTION OF CIRCUIT BREAKER, CONTACTORS, SWITCHING, 1 BRANCH CIRCUIT CONTACTING.					
FLEXIBLE SECTION					
ORCH. PLATFORM DOWNLIGHTS	1800 W	1	19	20A	
SPOTS & FLOODS (TYPICAL)	12000 W	24	20-43	20A	
FLOOR POZICITY	14000 W	14	44-57	20A	
AUDIT. CLG. 4 POTV	12000 W	24	58-81	20A	
ABOVE 63 FLEXIBLE CIRCUITS TO BE CONNECTED TO ANY OF 12 FEEDER POSITIONS BY 1/4 MEANS OF ROTARY TAP SWITCH PANEL TO BE FED BY 8 6000W DIMMER'S & 4 600A NON DIMMED FEEDER.					
CONDUIT SECTION					
DAKE - L 100' x 4	315	1	81	20A	
GRAND L 100' x 4					
CLOCK #100V VOLTAGE TRANS.		1	82	15A	
CONTACTOR: 400		1	83	15A	
GRABER		7	84-90	20A	
MAIN BUS, 412V TO BE 250A.					

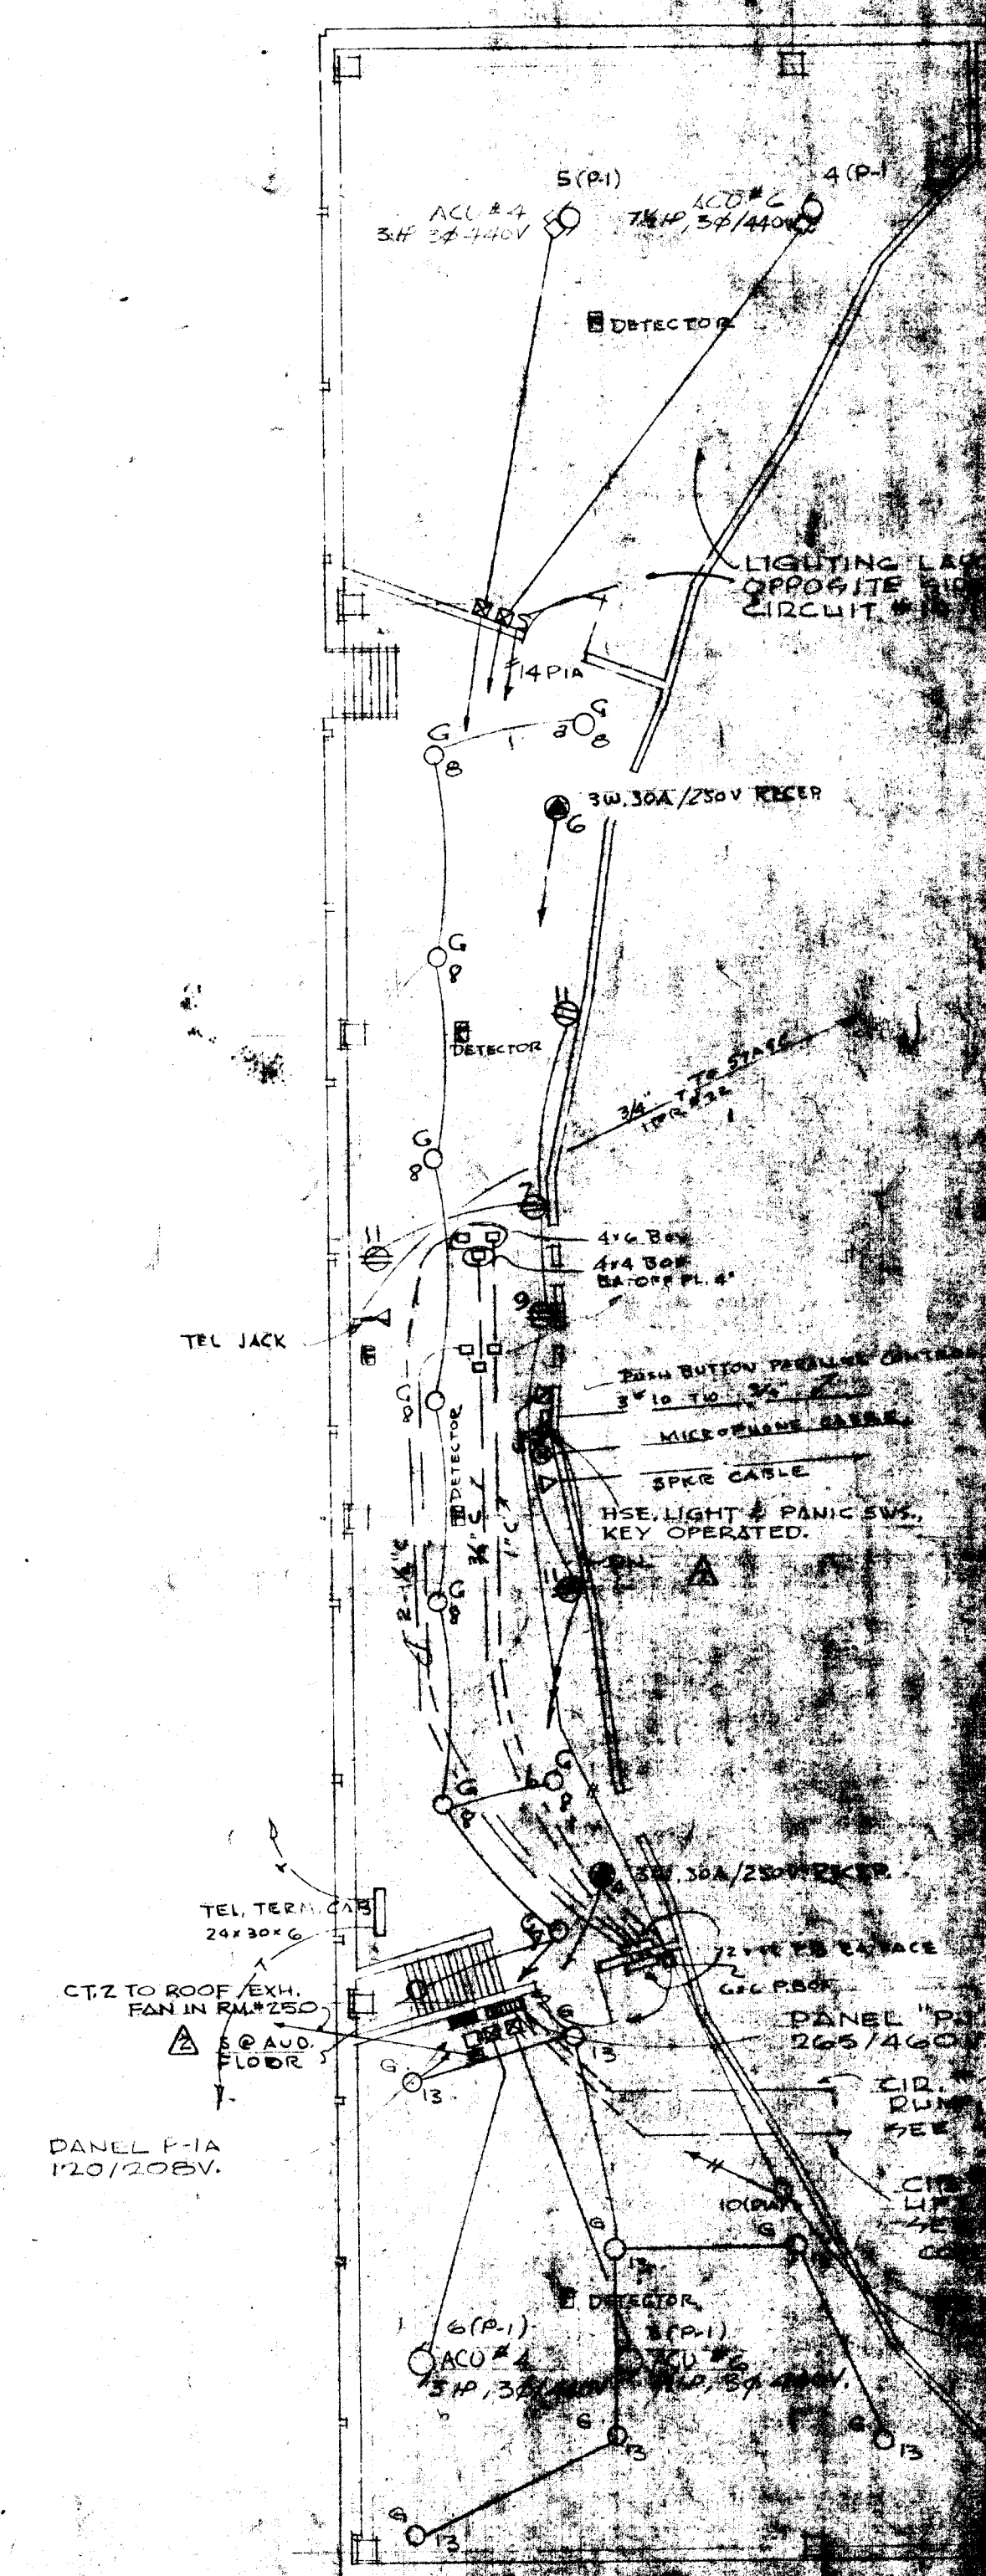

PROJECTION