

WRIGHT PORTER & LOWE INC.
ARCHITECTS - ENGINEERS
INDIANAPOLIS, INDIANA

ADMINISTRATION


Dr. Bernard K. McKenzie ,Supt.
John E. Newkirk, Admin. Asst.
W.C. Apple, Purchasing Direc.
Jack Okey, Facilities Engr.

[illegible]

M-1	Crestview Elementary School Unit 'A' - Tunnel Plan
M-2	Crestview Elementary School Unit 'B' & 'C' - Tunnel Plans
M-3	Crestview Elementary School Boiler Room Layouts, Details & Schedules
M-4	Harrison Hill Elementary School Unit 'A' - Tunnel Plan
M-5	Harrison Hill Elementary School Unit 'B' & 'C' - Tunnel Plans
M-6	Harrison Hill Elementary School Boiler Room Layouts, Details & Schedules
M-7	Brook Park Elementary School Unit 'A' - Tunnel Plan - Boiler Room
M-8	Brook Park Elementary School Unit 'B' & 'C' - Tunnel Plan - Gymnasium
M-9	Lawrence Central High School Unit 'A' - Floor Plan
M-10	Lawrence Central High School Unit 'B' - Floor Plan
M-11	Lawrence Central High School Unit 'C' - Floor Plan
M-12	Lawrence Central High School Unit 'F' - Floor Plan
M-13	Lawrence Central High School Boiler Room Layout, Details & Schedules, Incinerator

WRIGHT/PORTEOUS & LOWE INC.

COGHILL/OBERLIES & ASSOC. INC.

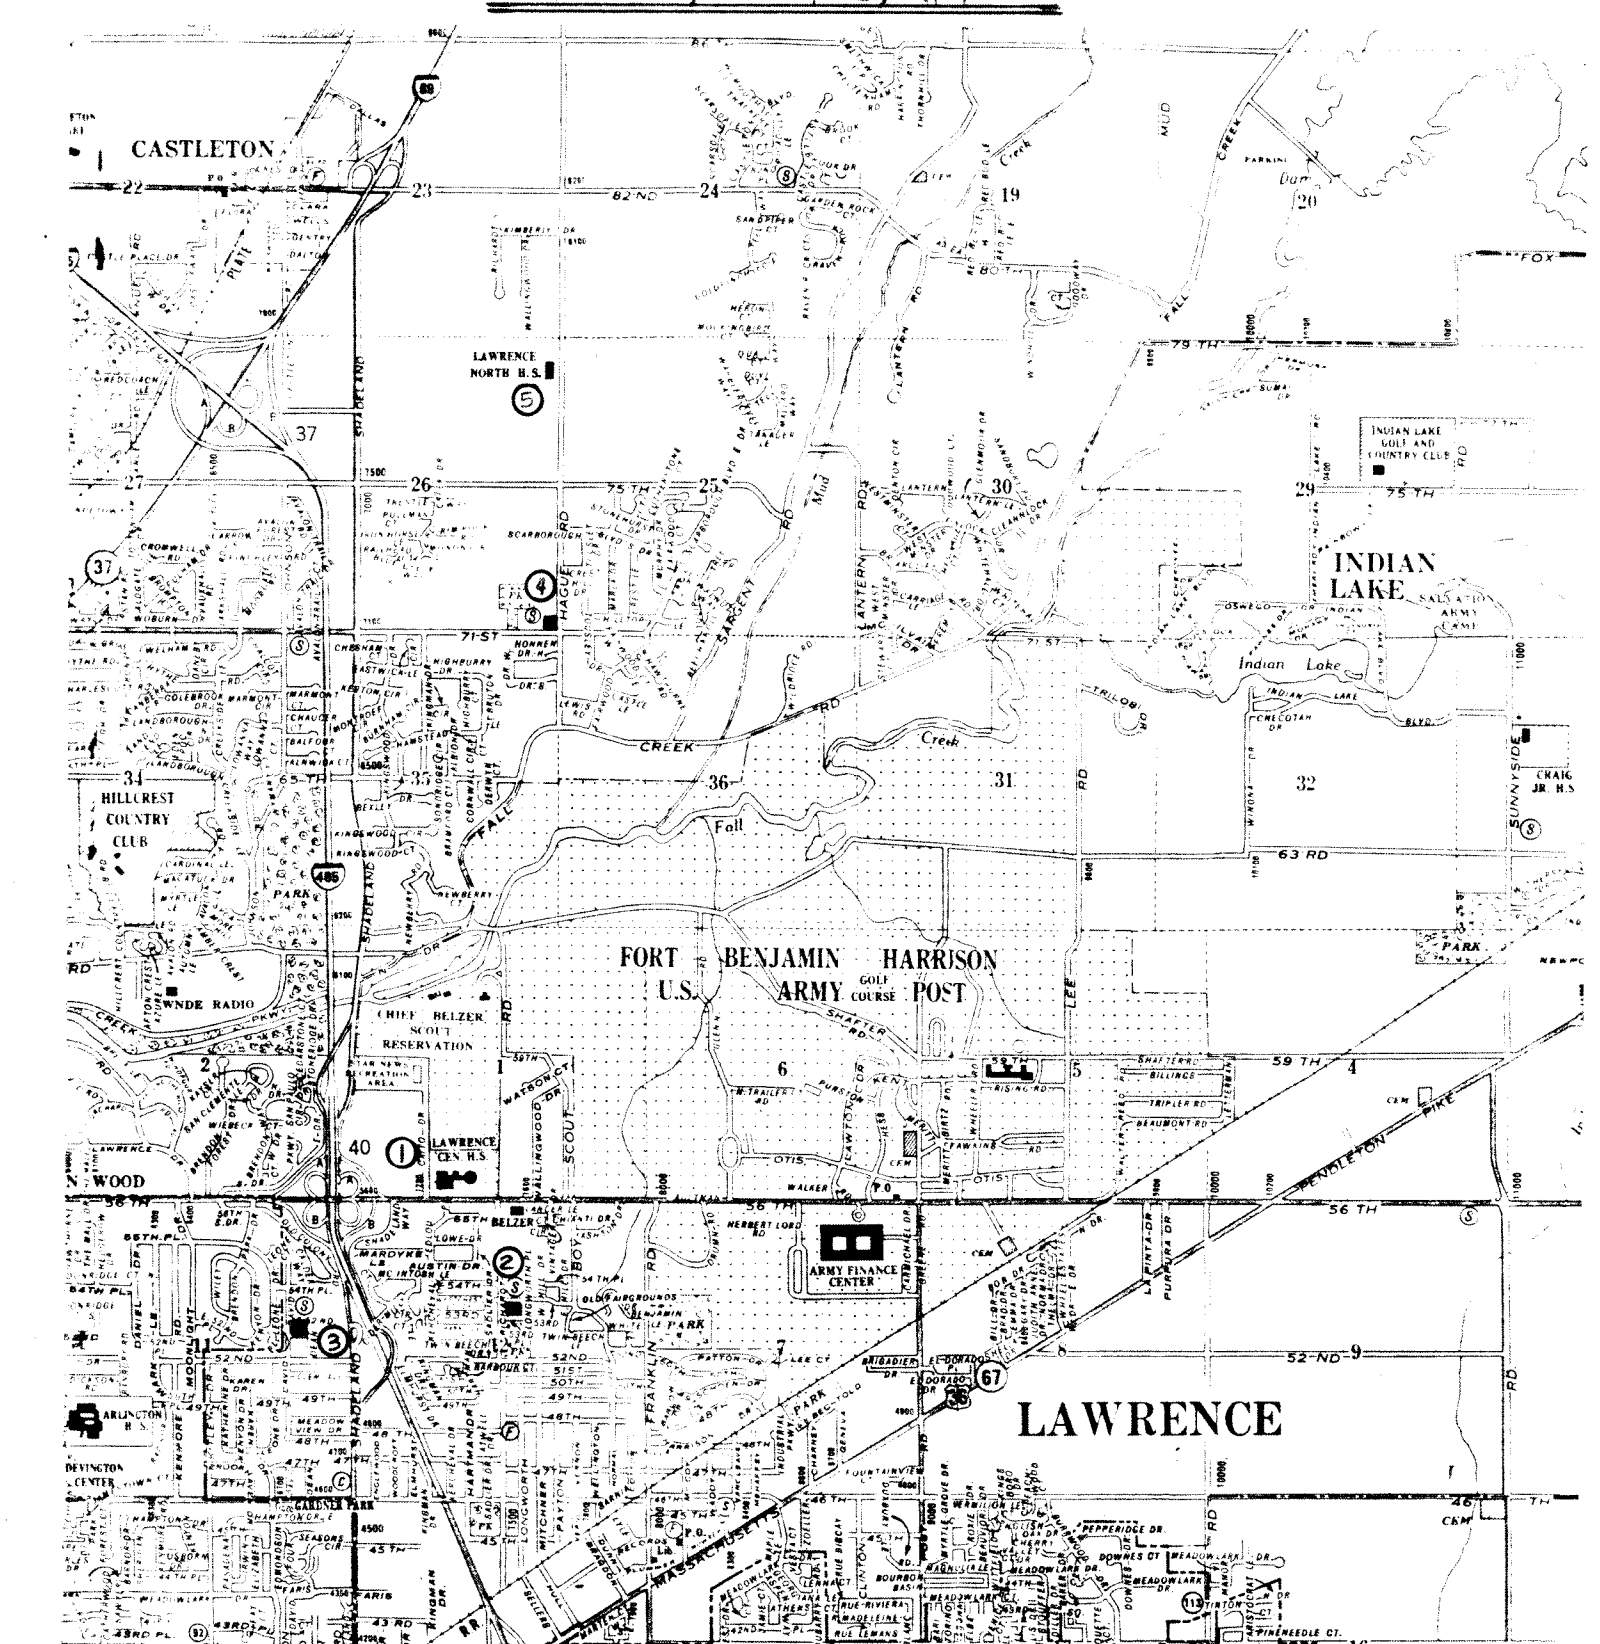


PROJECT SITES: ① LAWRENCE CENTRAL HIGH SCHOOL
② HARRISON HILL ELEMENTARY SCHOOL
③ BLOOM PARK ELEMENTARY SCHOOL
④ CRESTVIEW ELEMENTARY SCHOOL
⑤ LAWRENCE NORTH HIGH SCHOOL



SHEET


F

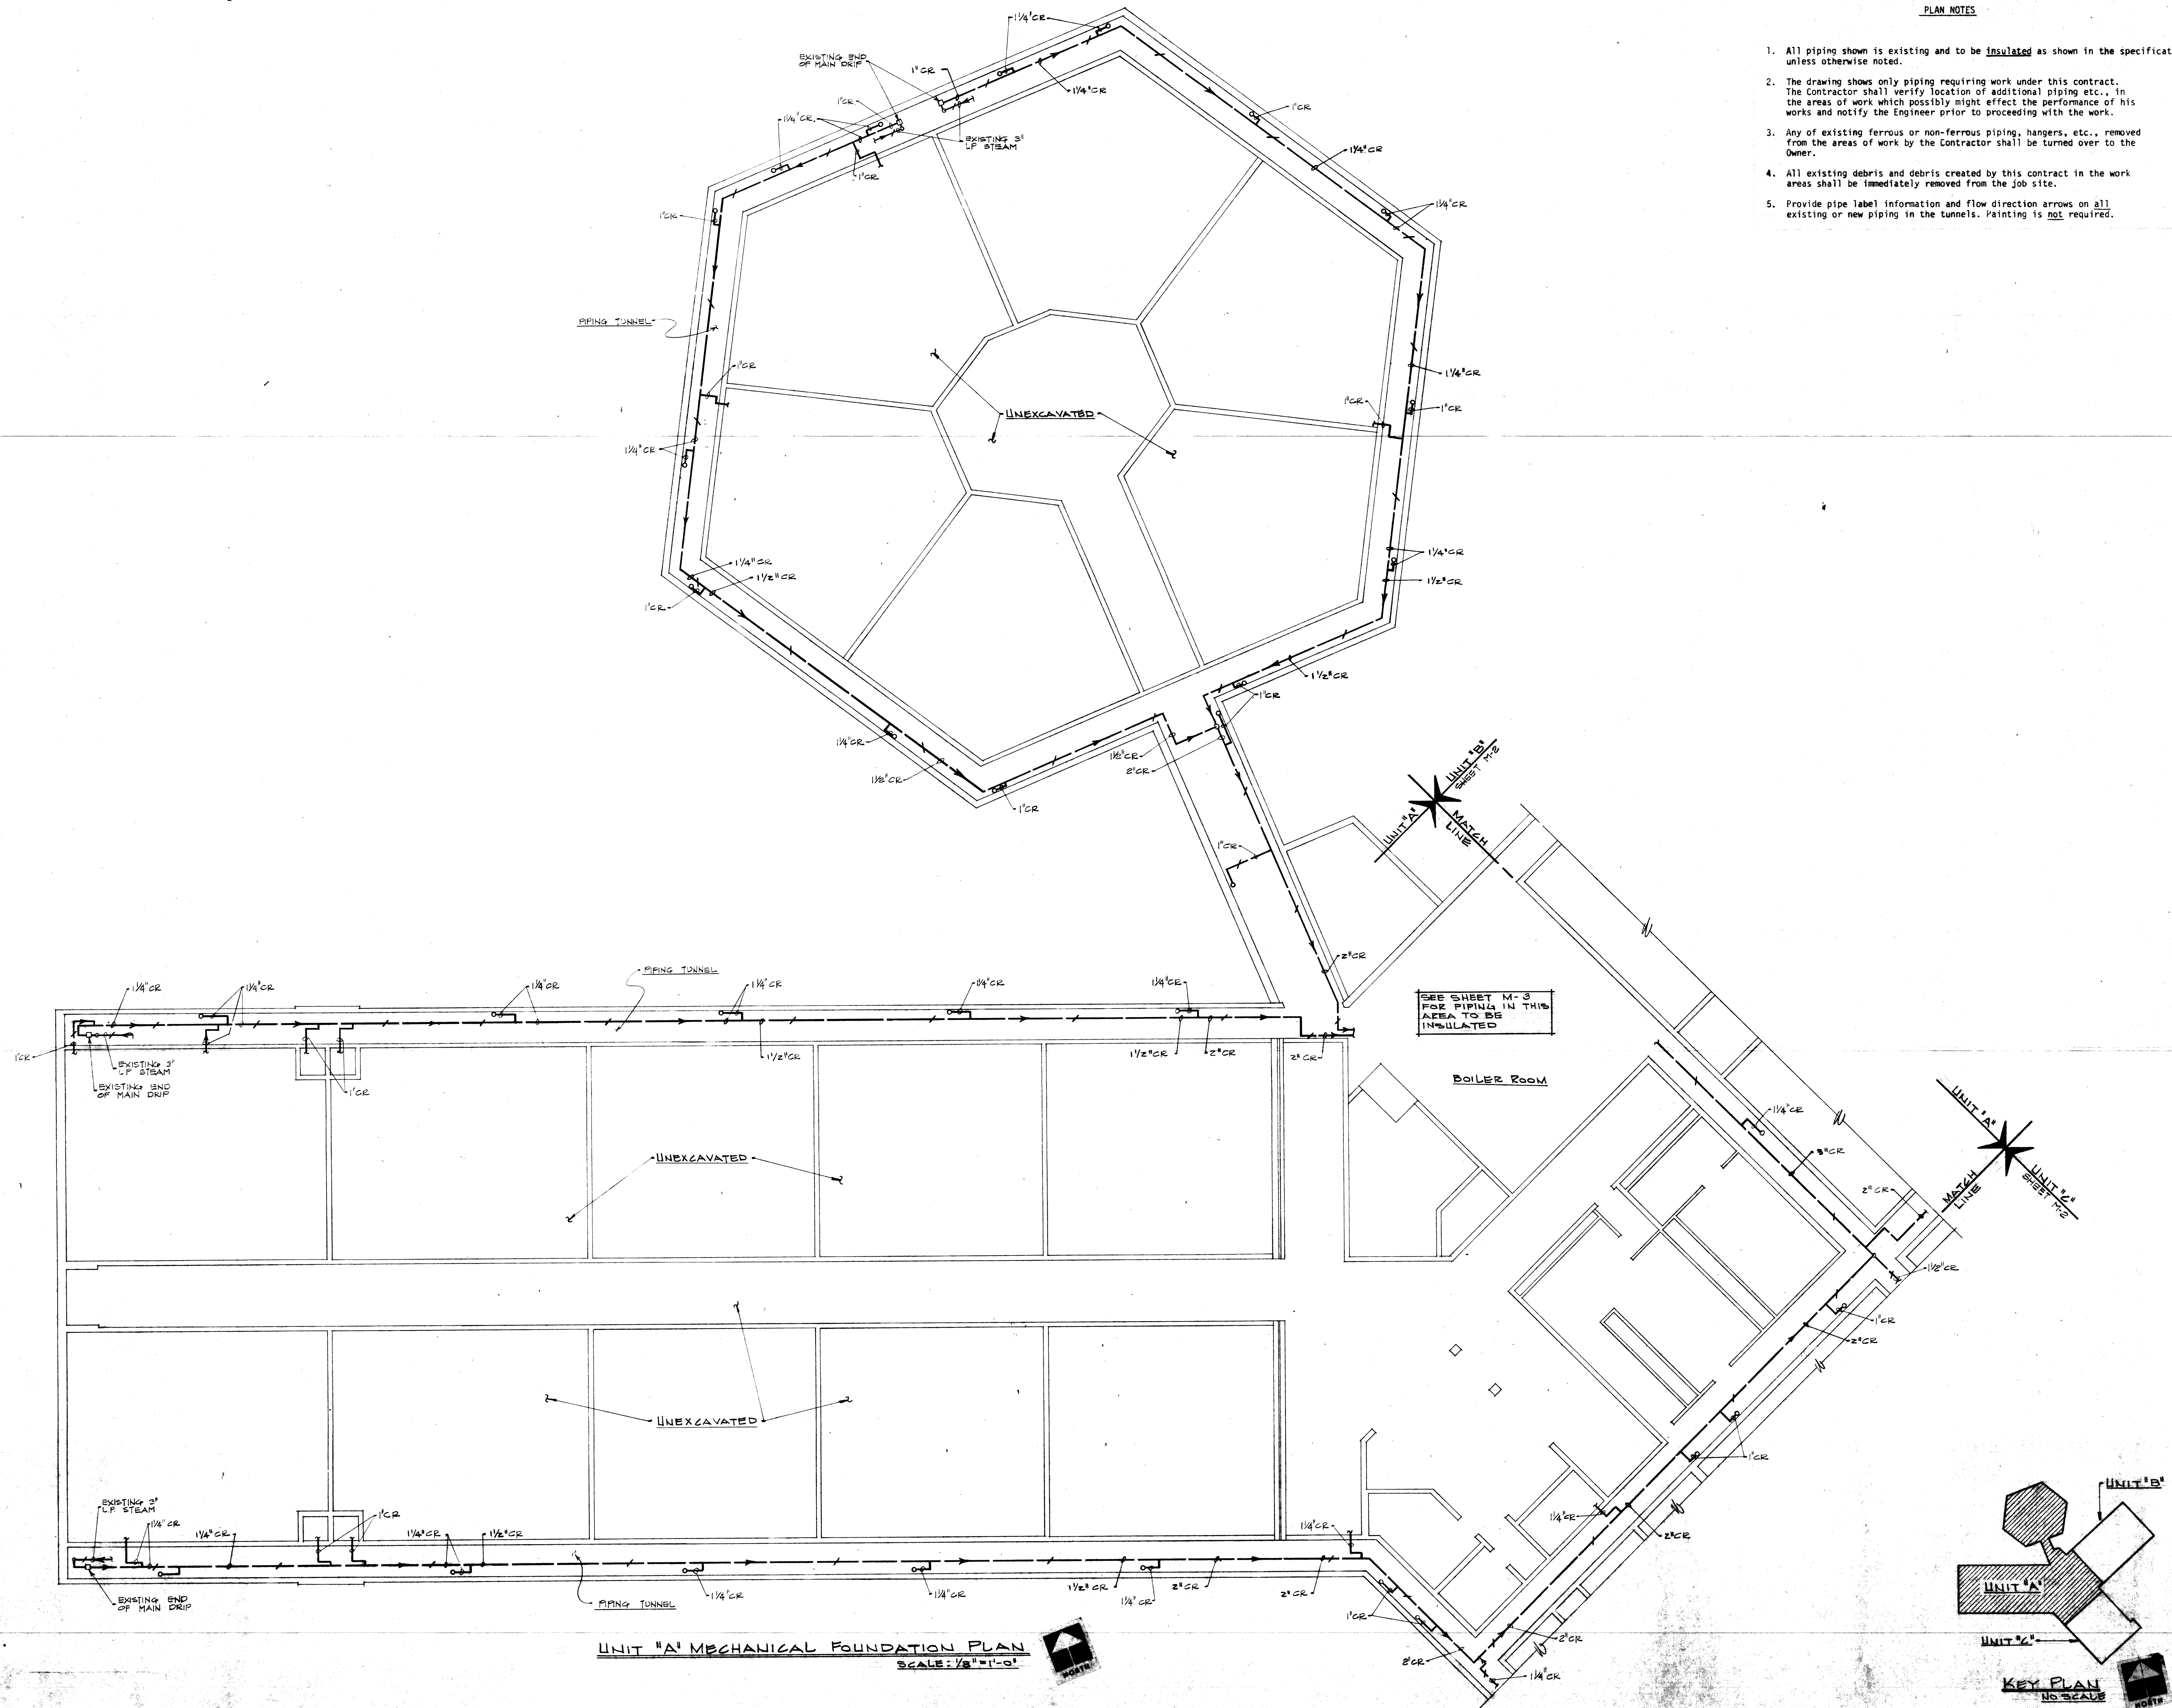

PLAN NOTES

1. All piping shown is existing and to be insulated as shown in the specifications unless otherwise noted.
2. The drawing shows only piping requiring work under this contract. The Contractor shall verify location of additional piping etc., in the areas of work which possibly might effect the performance of his works and notify the Engineer prior to proceeding with the work.
3. Any of existing ferrous or non-ferrous piping, hangers, etc., removed from the areas of work by the Contractor shall be turned over to the Owner.
4. All existing debris and debris created by this contract in the work areas shall be immediately removed from the job site.
5. Provide pipe label information and flow direction arrows on all existing or new piping in the tunnels. Painting is not required.

UNIT "A" MECHANICAL FOUNDATION PLAN
SCALE: 1/8" = 1'-0"

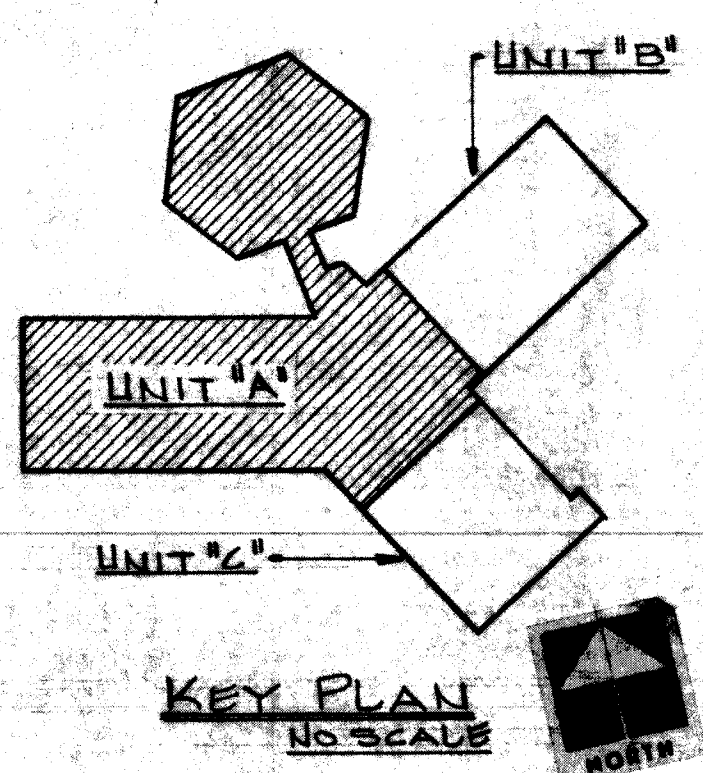

WRIGHT PORTER & LOWE INC.
ARCHITECTS ENGINEERS
COGILL/OBERLIES & ASSOCIATES
Consulting Engineers
INDIANAPOLIS, INDIANA


UNIT A - TUNNEL PLAN

METROPOLITAN SCHOOL DISTRICT
OF LAWRENCE TOWNSHIP
CRESTVIEW ELEMENTARY SCHOOL

REVISIONS		CONTRACT NO.	DATE	DATE	DATE	DATE	DATE
NO.	DESCRIPTION	8/20/01	11/30/01	1/30/02	3/20/02	5/20/02	7/20/02

UNIT "A" MECHANICAL FOUNDATION PLAN
SCALE: 1/8" = 1'-0"

M-1
OF 13

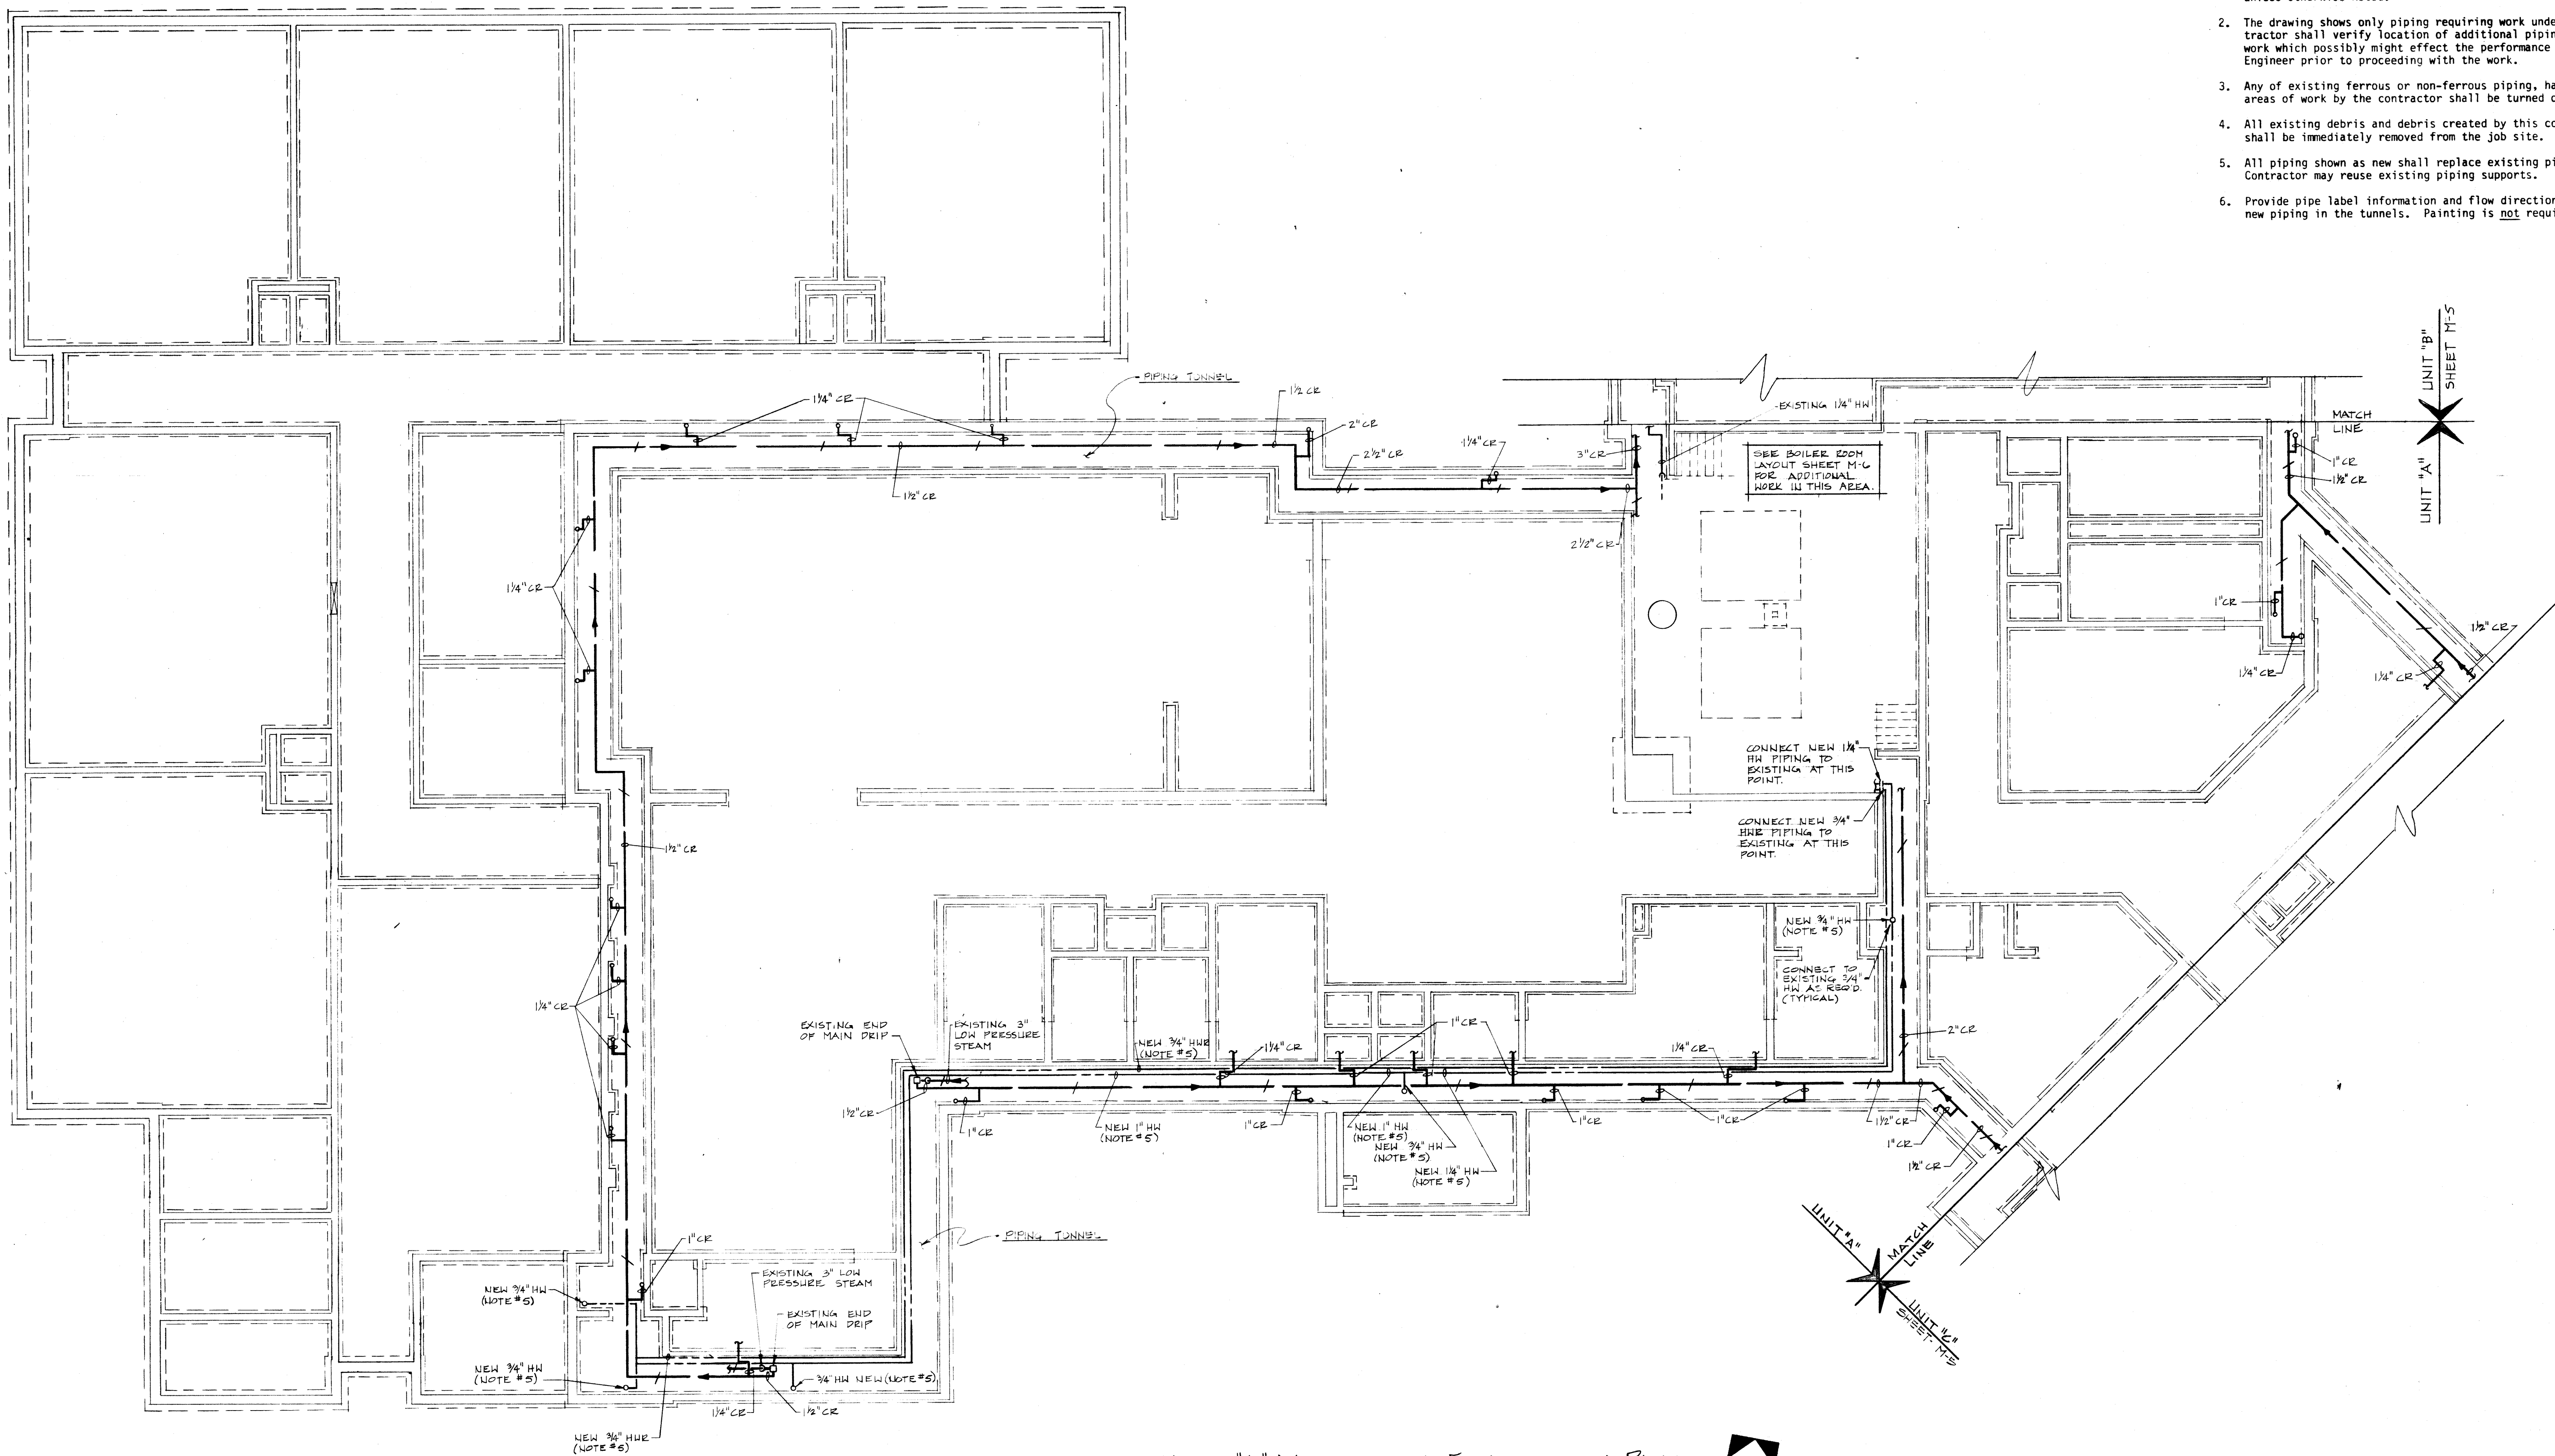

UNIT "A" MECHANICAL FOUNDATION PLAN
SCALE: 1/8"=1'-0"




PLAN NOTES

1. All piping shown is existing and to be insulated as shown in the specifications unless otherwise noted.
2. The drawing shows only piping requiring work under this contract. The Contractor shall verify location of additional piping, etc., in the areas of work which possibly might effect the performance of his works and notify the Engineer prior to proceeding with the work.
3. Any of existing ferrous or non-ferrous piping, hangers, etc. removed from the areas of work by the contractor shall be turned over to the Owner.
4. All existing debris and debris created by this contract in the work areas shall be immediately removed from the job site.
5. All piping shown as new shall replace existing piping in the same location. Contractor may reuse existing piping supports.
6. Provide pipe label information and flow direction arrows on all existing or new piping in the tunnels. Painting is not required.

UNIT "B"
SHEET M-5

UNIT "A"
SHEET M-5

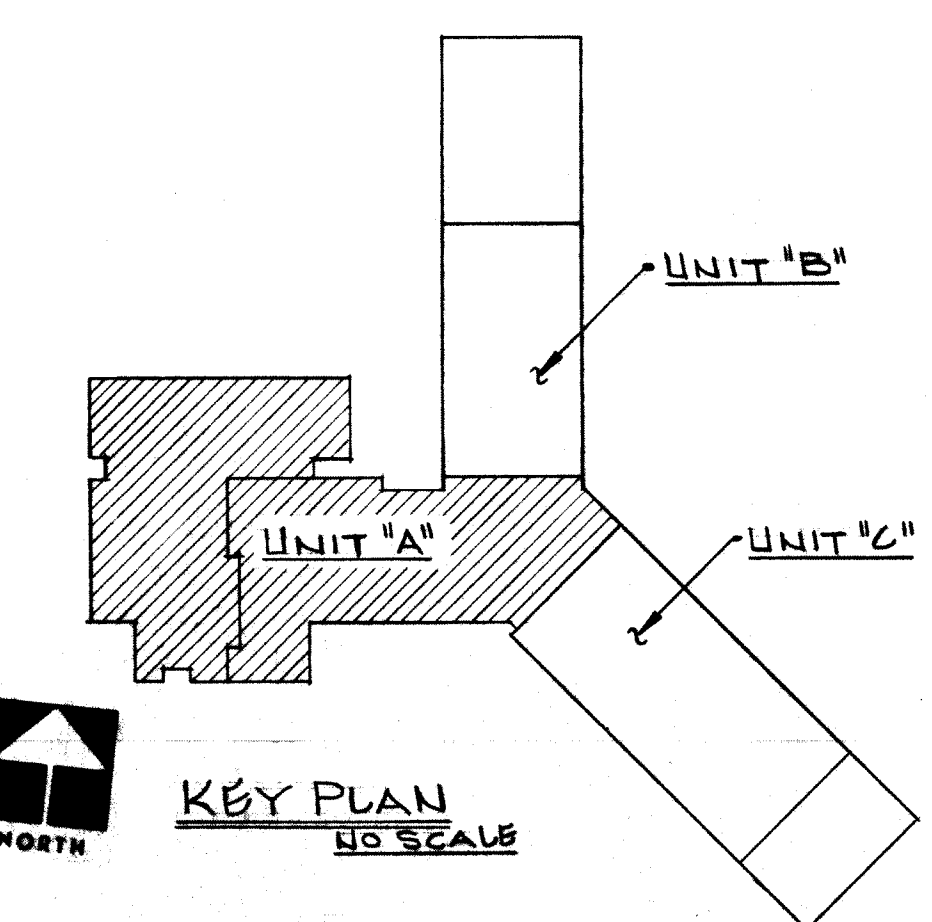

KEY PLAN
NO SCALE


WRIGHT PORTER & LOWE INC.
ARCHITECTS - ENGINEERS
INDIANAPOLIS, INDIANA


COGHILL/OBERLIES & ASSOCIATES
Consulting Engineers
INDIANAPOLIS, INDIANA

UNIT A - TUNNEL PLAN

METROPOLITAN SCHOOL DISTRICT
OF LAWRENCE TOWNSHIP
HARRISON HILL ELEMENTARY SCHOOL


NO.	DATE	REVISIONS	DESCRIPTION	CONC. NO.	DATE
1	8/20/81				
2	1/30/81				
3	3/2/81				
4	5/2/81				
5	5/2/81				

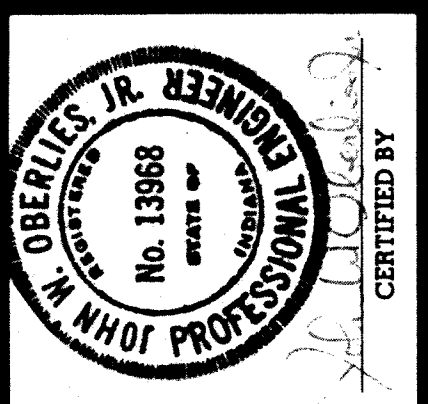




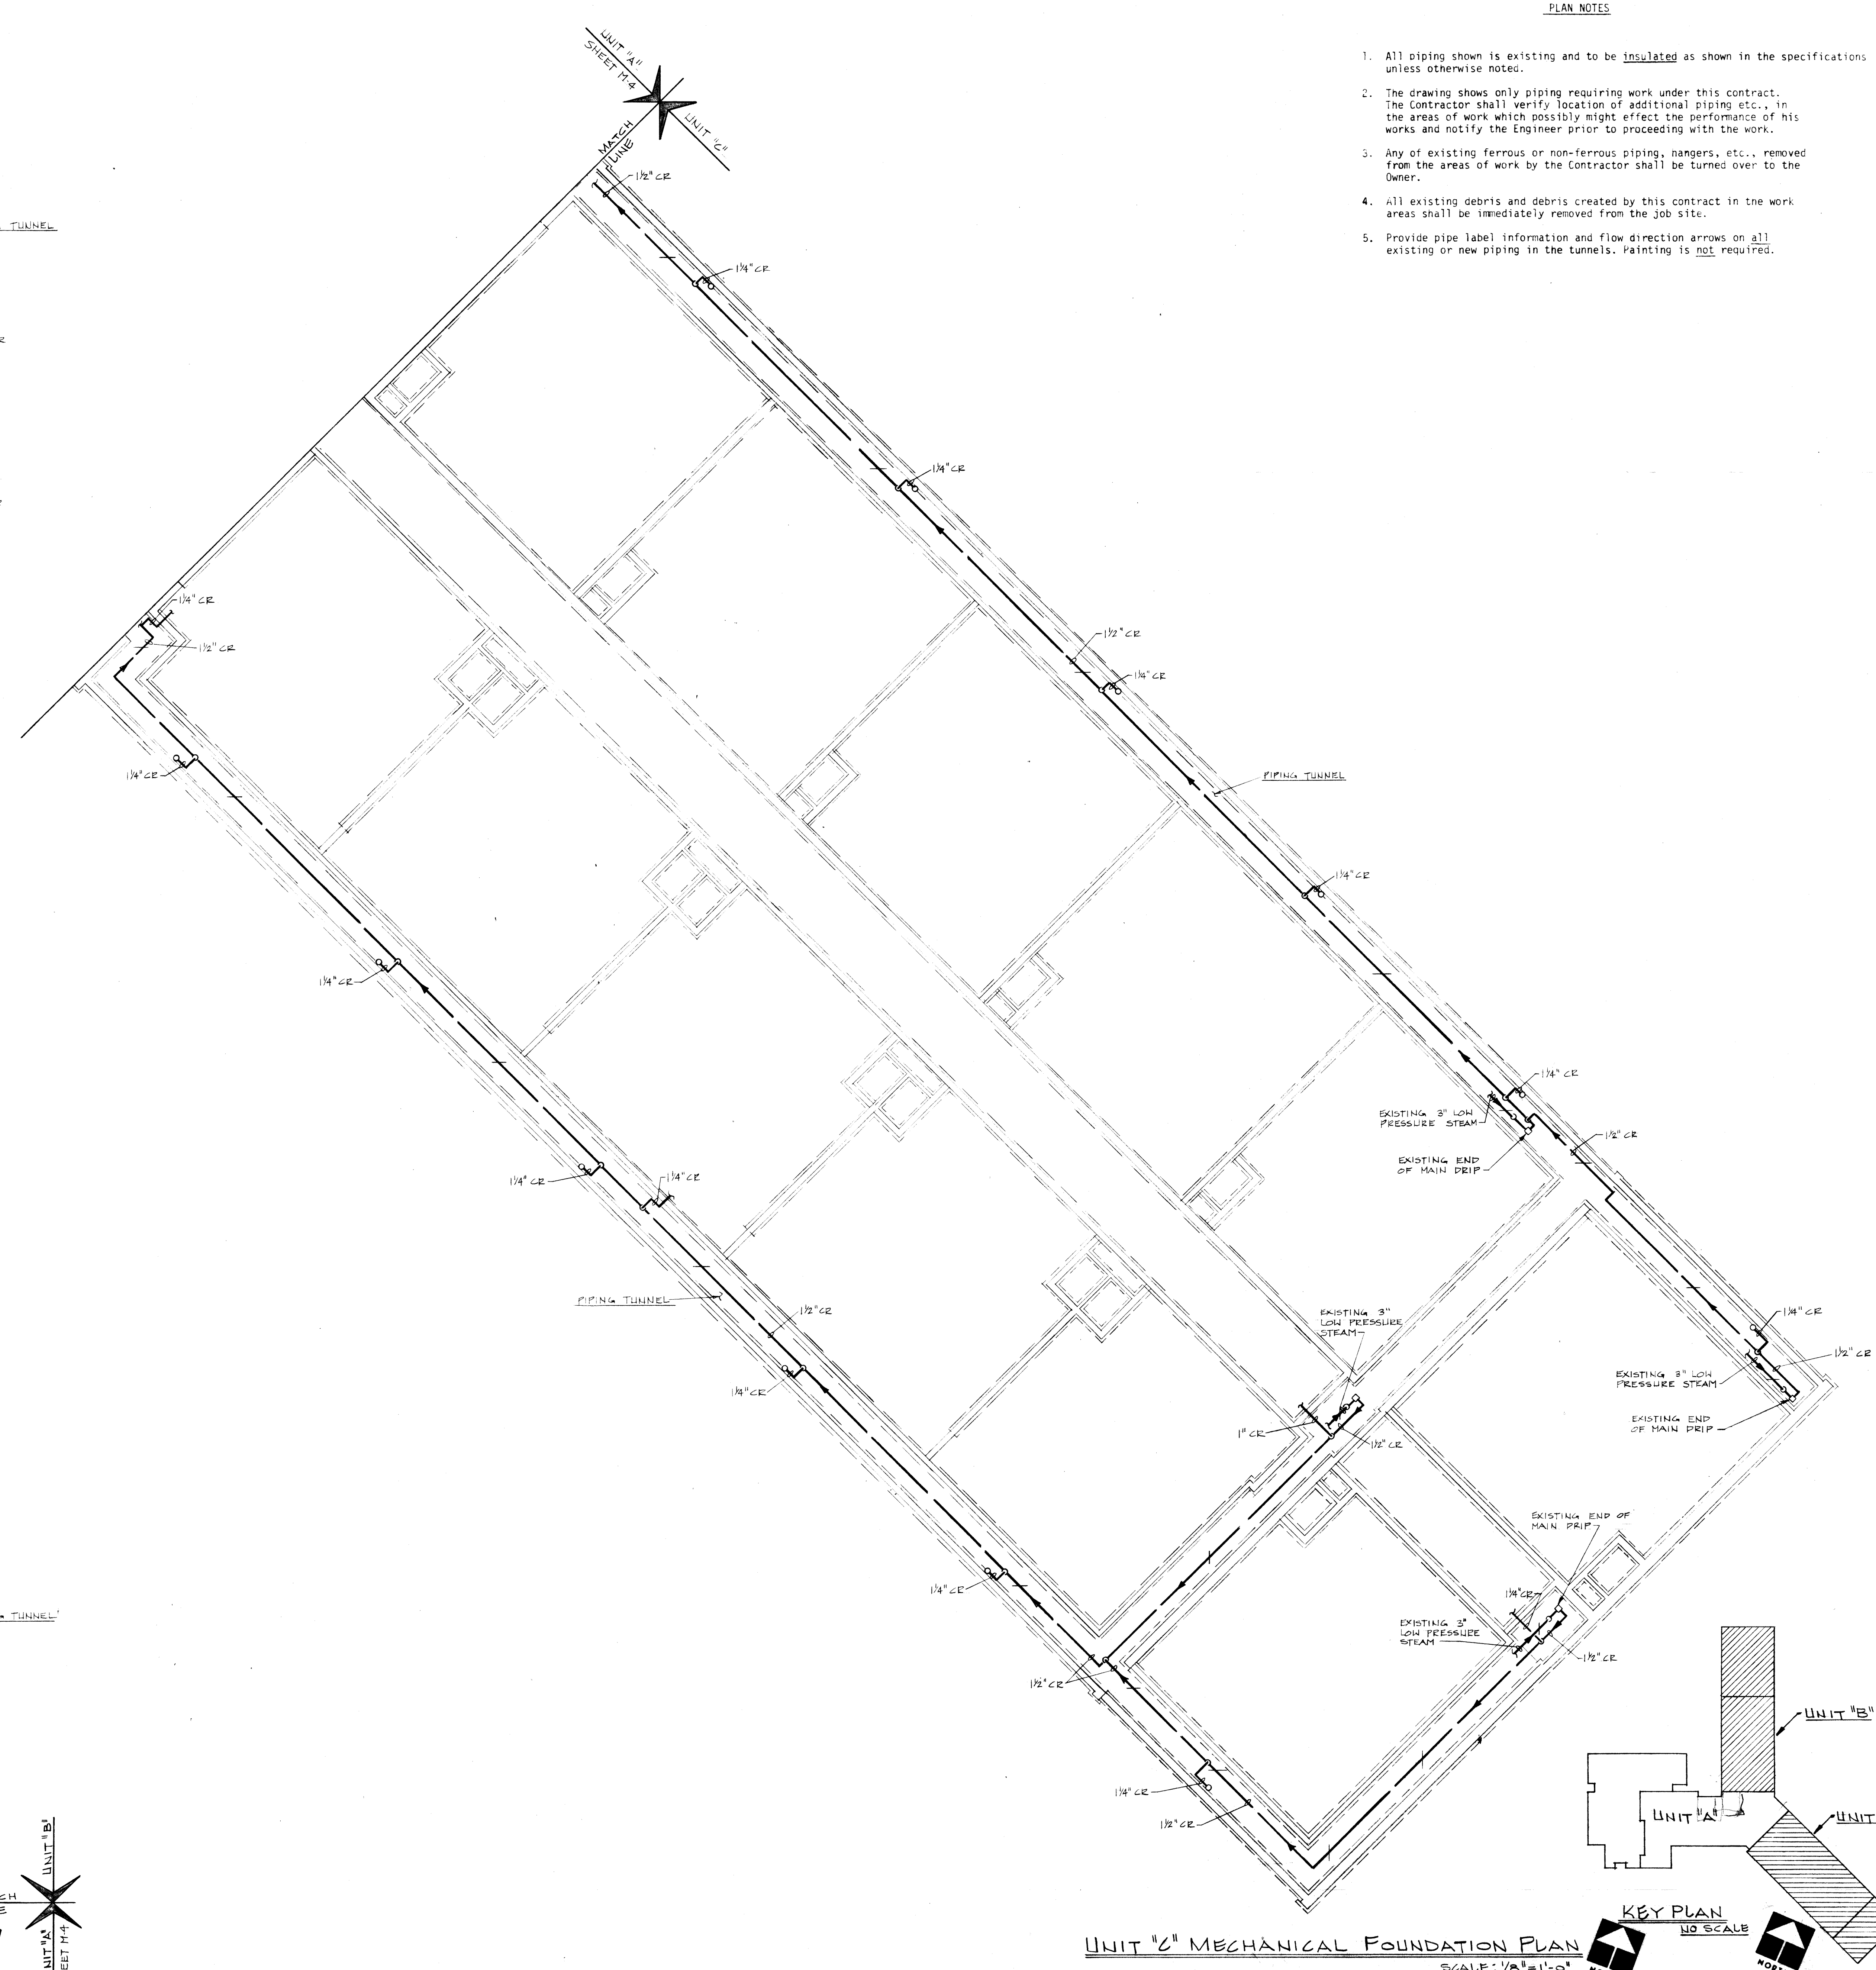



1. All piping shown is existing and to be insulated as shown in the specifications unless otherwise noted.
2. The drawing shows only piping requiring work under this contract. The Contractor shall verify location of additional piping etc., in the areas of work which possibly might effect the performance of his works and notify the Engineer prior to proceeding with the work.
3. Any of existing ferrous or non-ferrous piping, hangers, etc., removed from the areas of work by the Contractor shall be turned over to the Owner.
4. All existing debris and debris created by this contract in the work areas shall be immediately removed from the job site.
5. Provide pipe label information and flow direction arrows on all existing or new piping in the tunnels. Painting is not required.

[illegible]

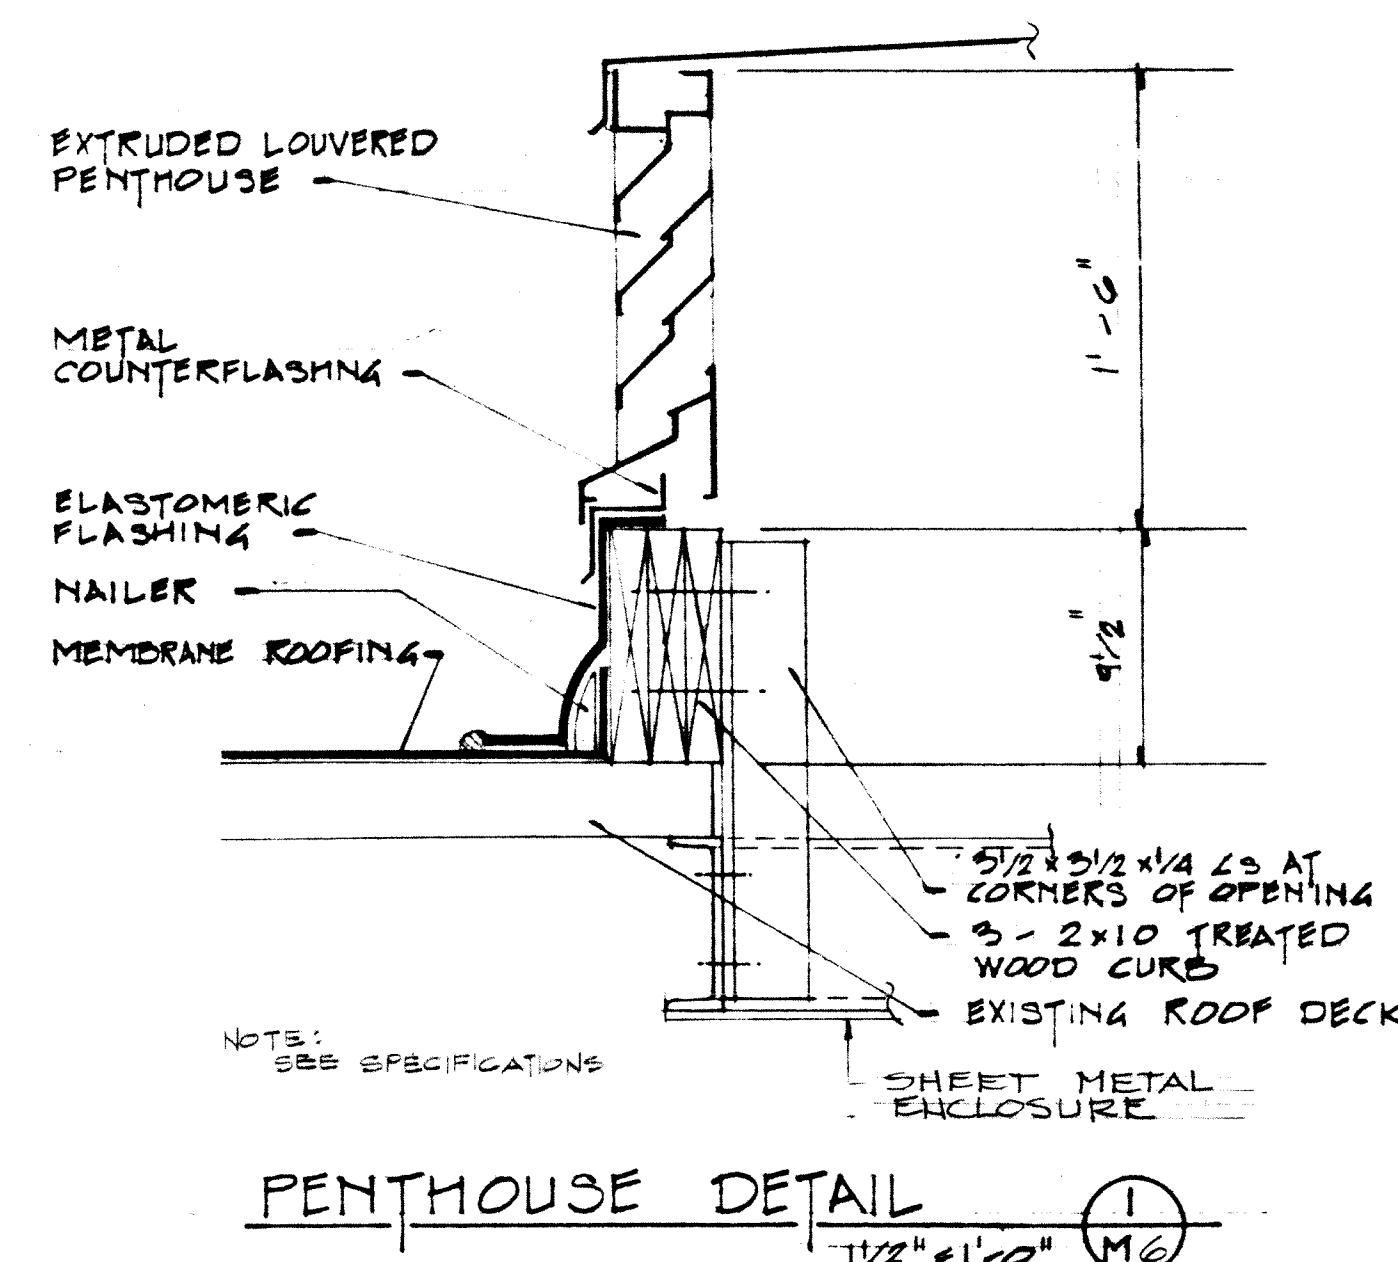

- ## BOILER ROOM MECHANICAL EQUIPMENT SCHEDULE
1. New Heating System Boiler #1 & 2:
Bryan Model L-64-S, or an approved equal. Gross output rating 3440 MBH., 100 boiler horsepower, water tube, 520 square feet heating surface.
 2. New Heating System Burner #1 & 2:
Industrial Combustion Model GL6 or an approved equal, combination gas-oil burner, gas capacity, 4200 cubic feet per hour of 0.6 specific gravity, 1000 BTU cubic inch of liquid gas at a maximum manifold pressure of 6" water column. Oil capacity 30 gallons per hour with a heat content of 140,000 BTU per gallon. Burner Motor Data: 2 HP, 208 volts, 3 phase, 60 hertz.
 3. New Backflow Preventer
Hersey, Watts, or an approved equal - see specifications.
 4. Fuel Oil Pump Set:
Acc pump set number 28, pump number 2CS or an approved equal. Capacity will be 150 GPH measured at 15" HG vacuum and 50 PSIG head with #2 fuel oil. Pump motor (2) 1/2 HP, 120 volt, 1 phase, 1750 RPM.

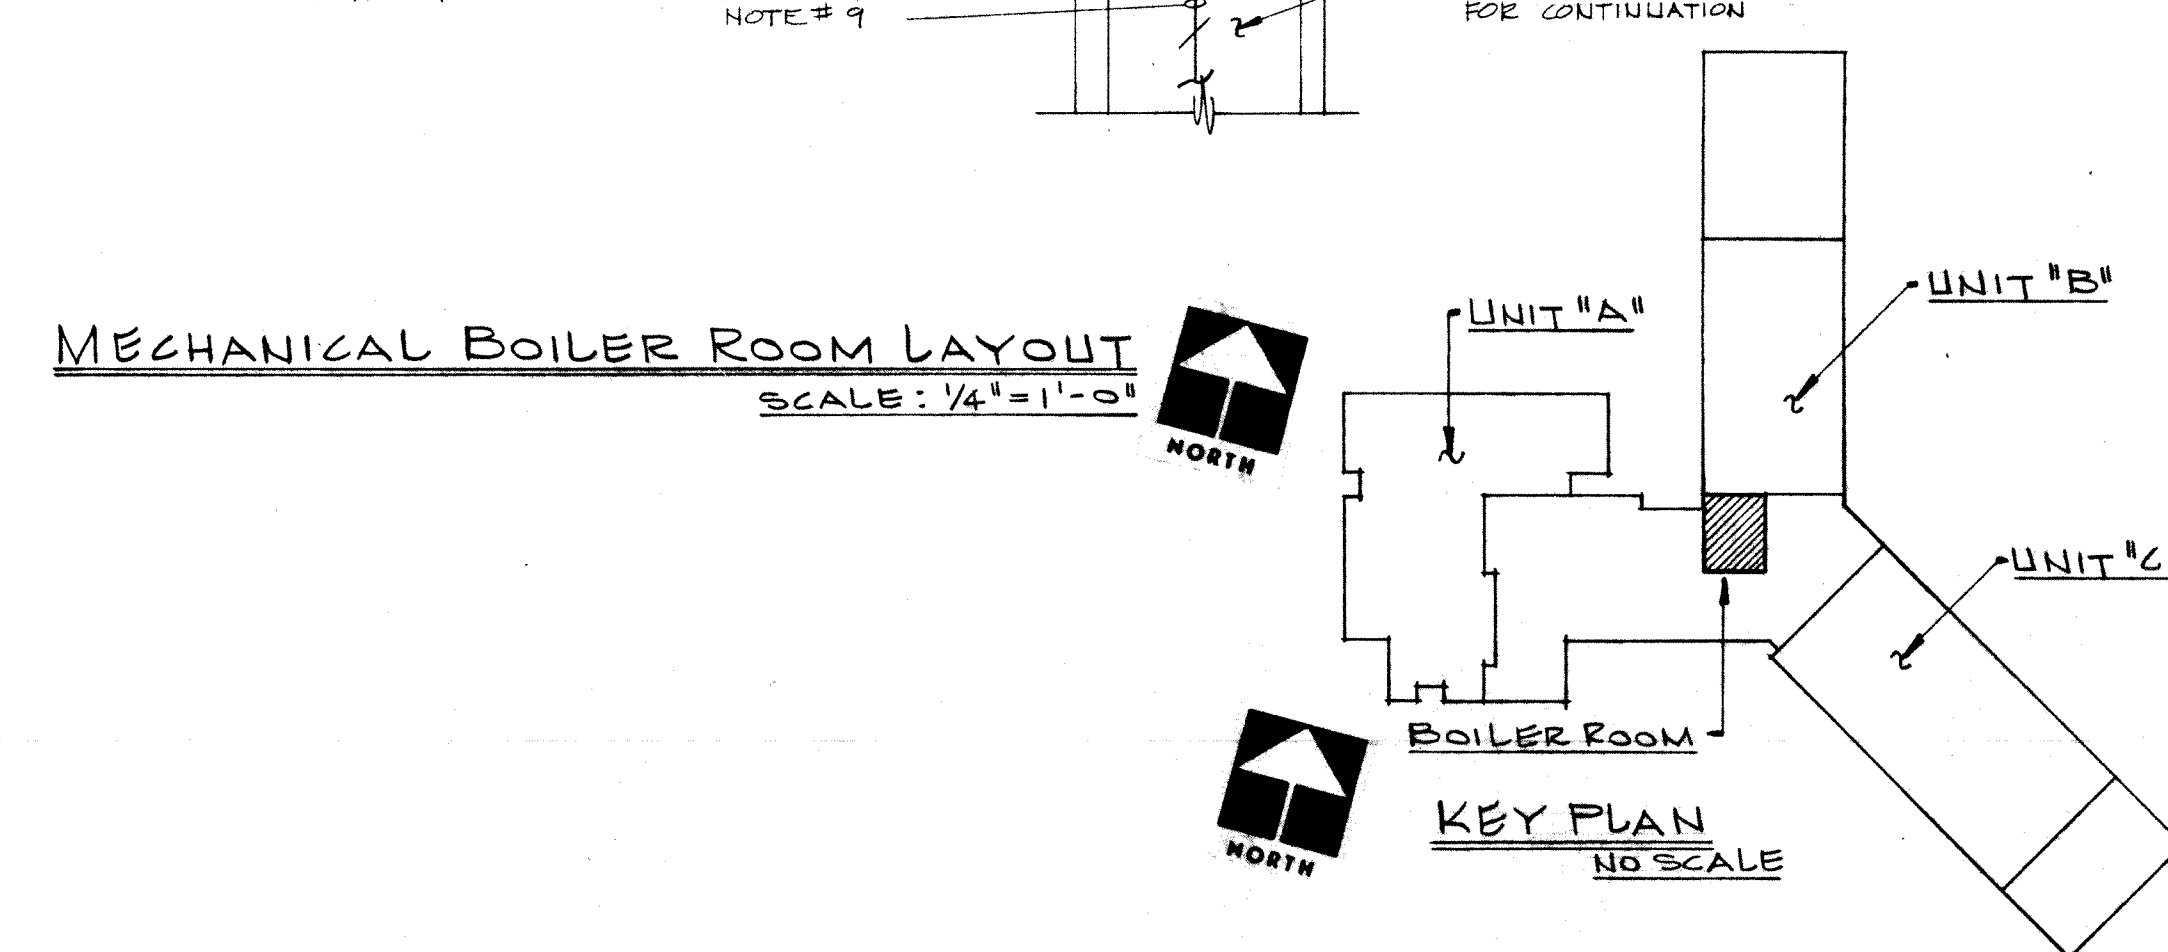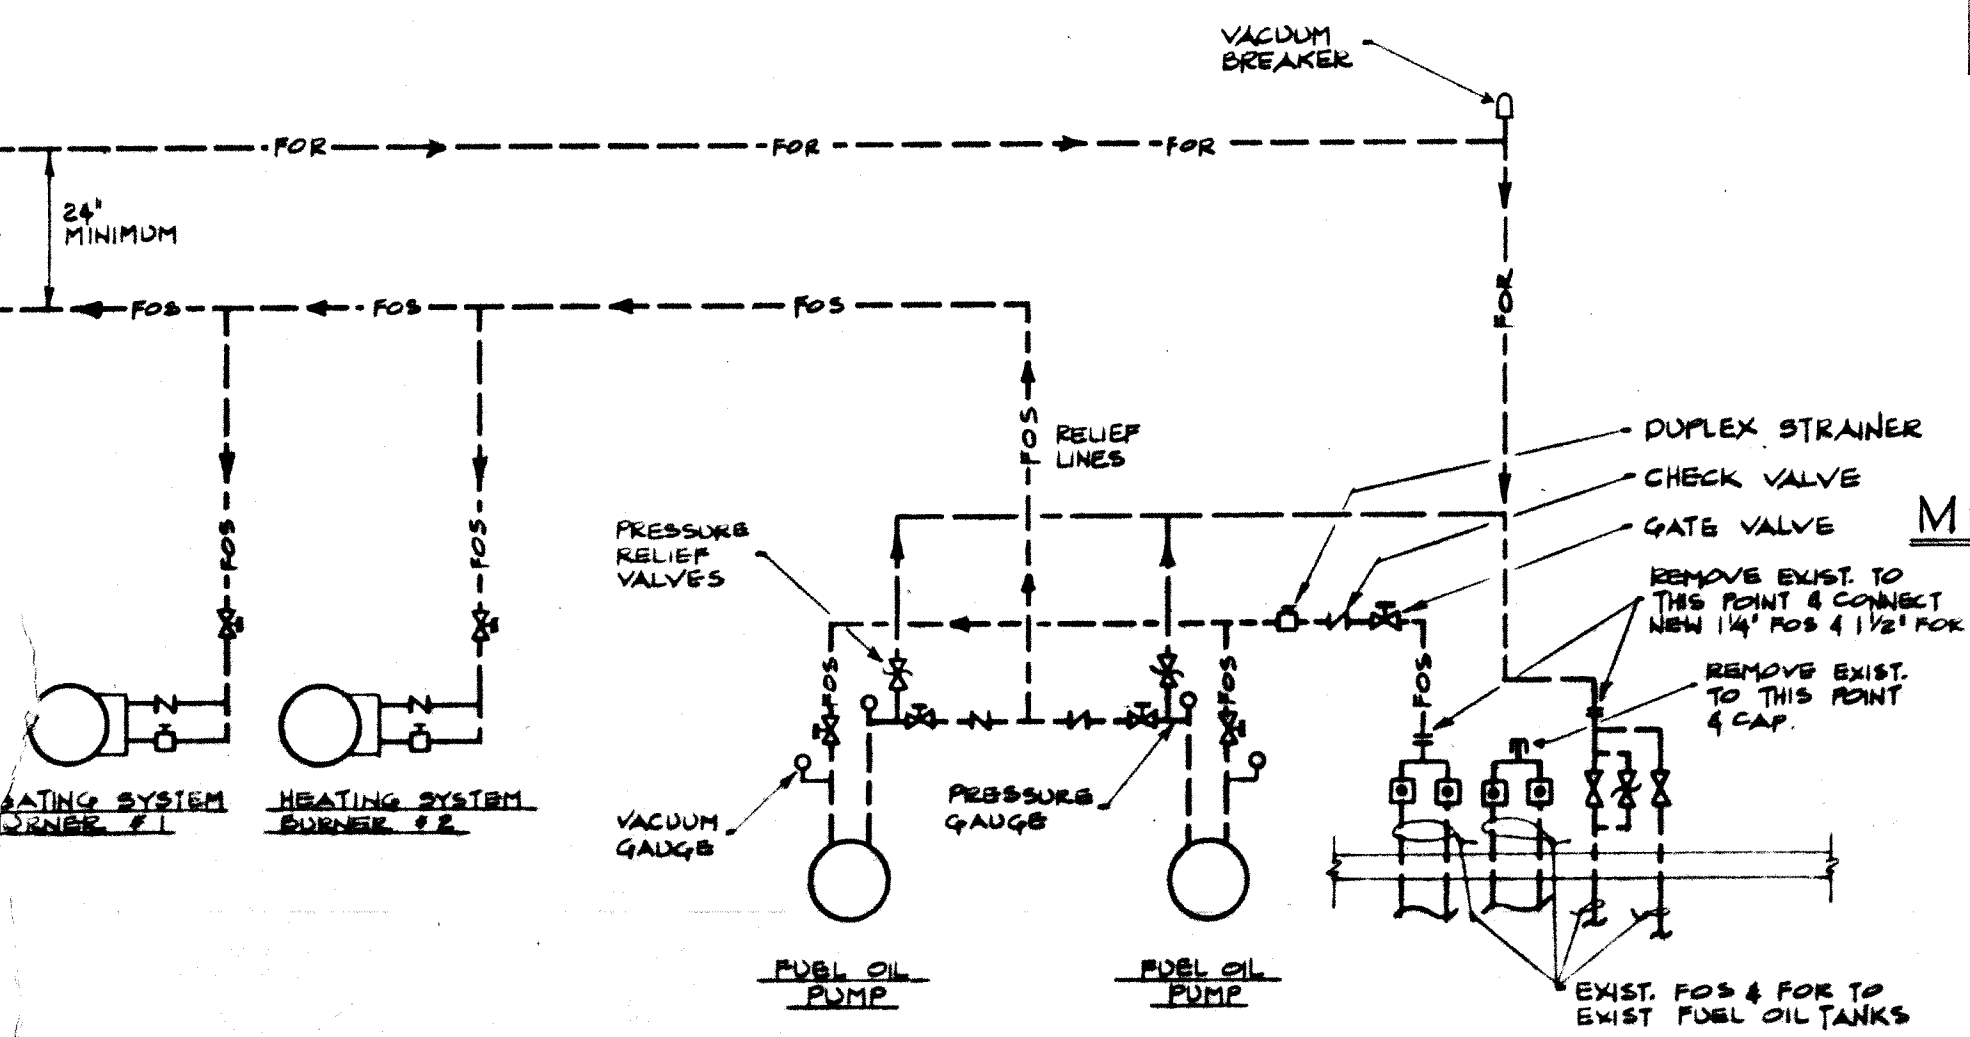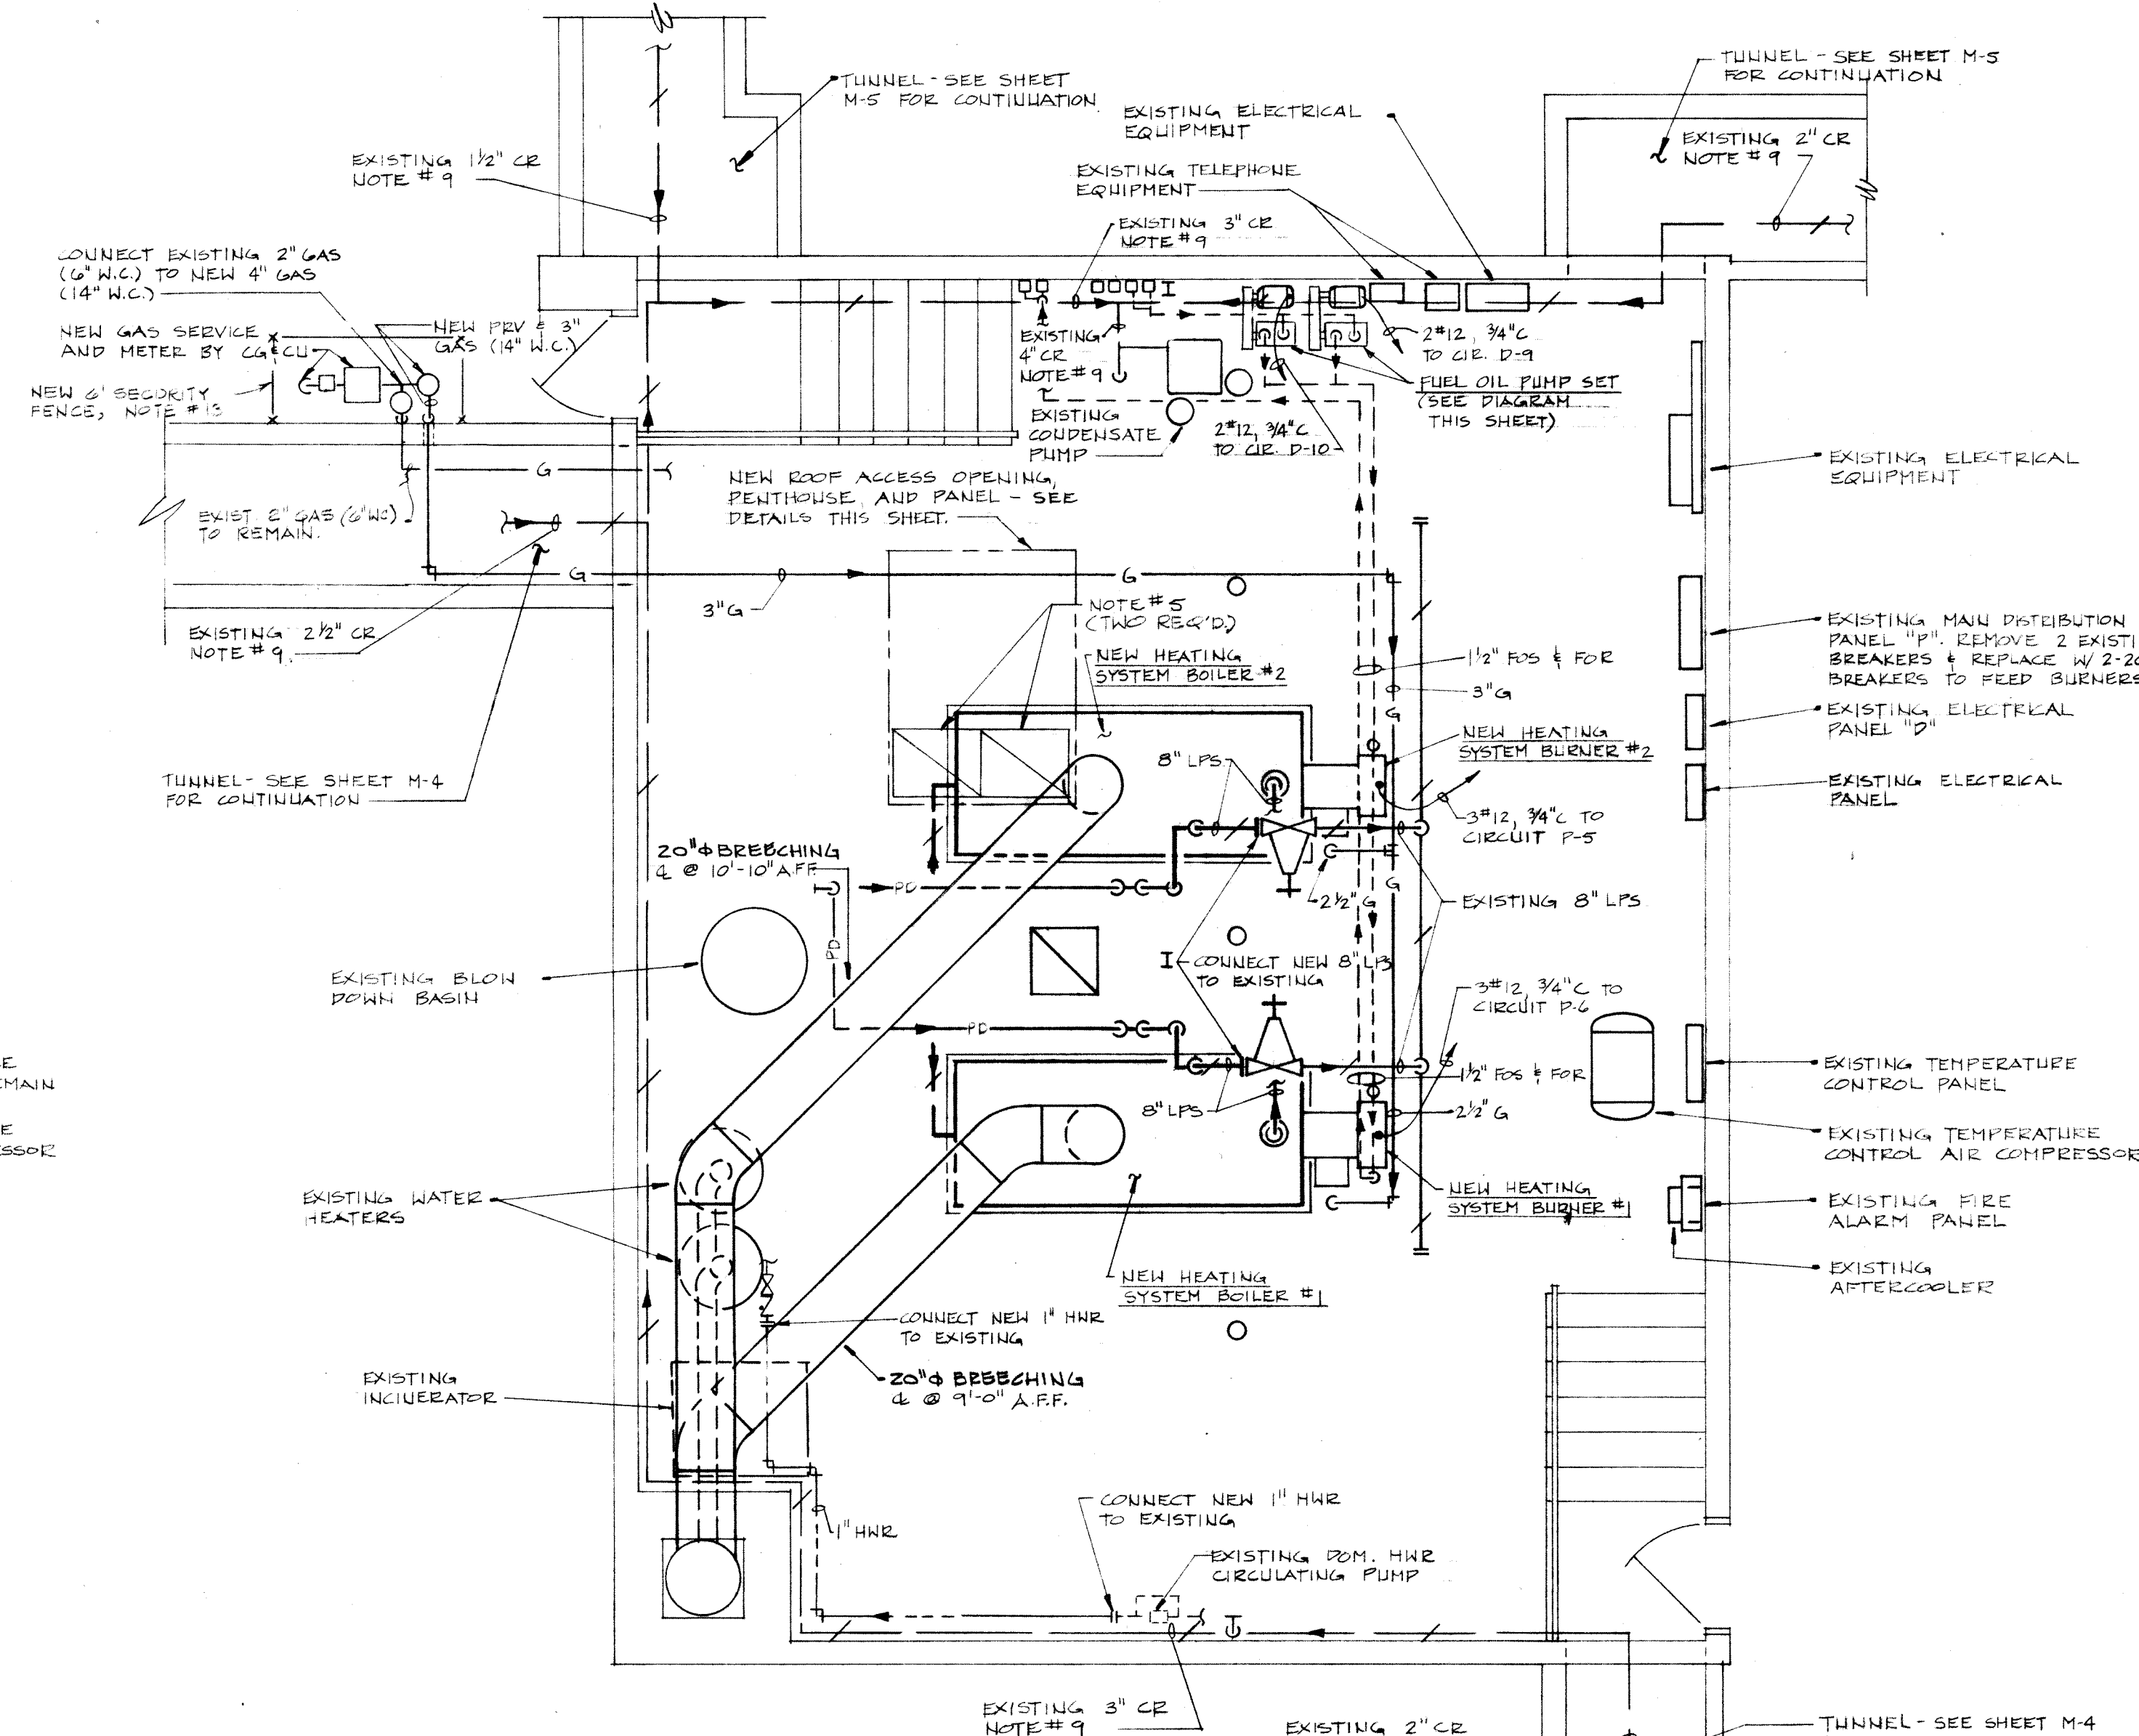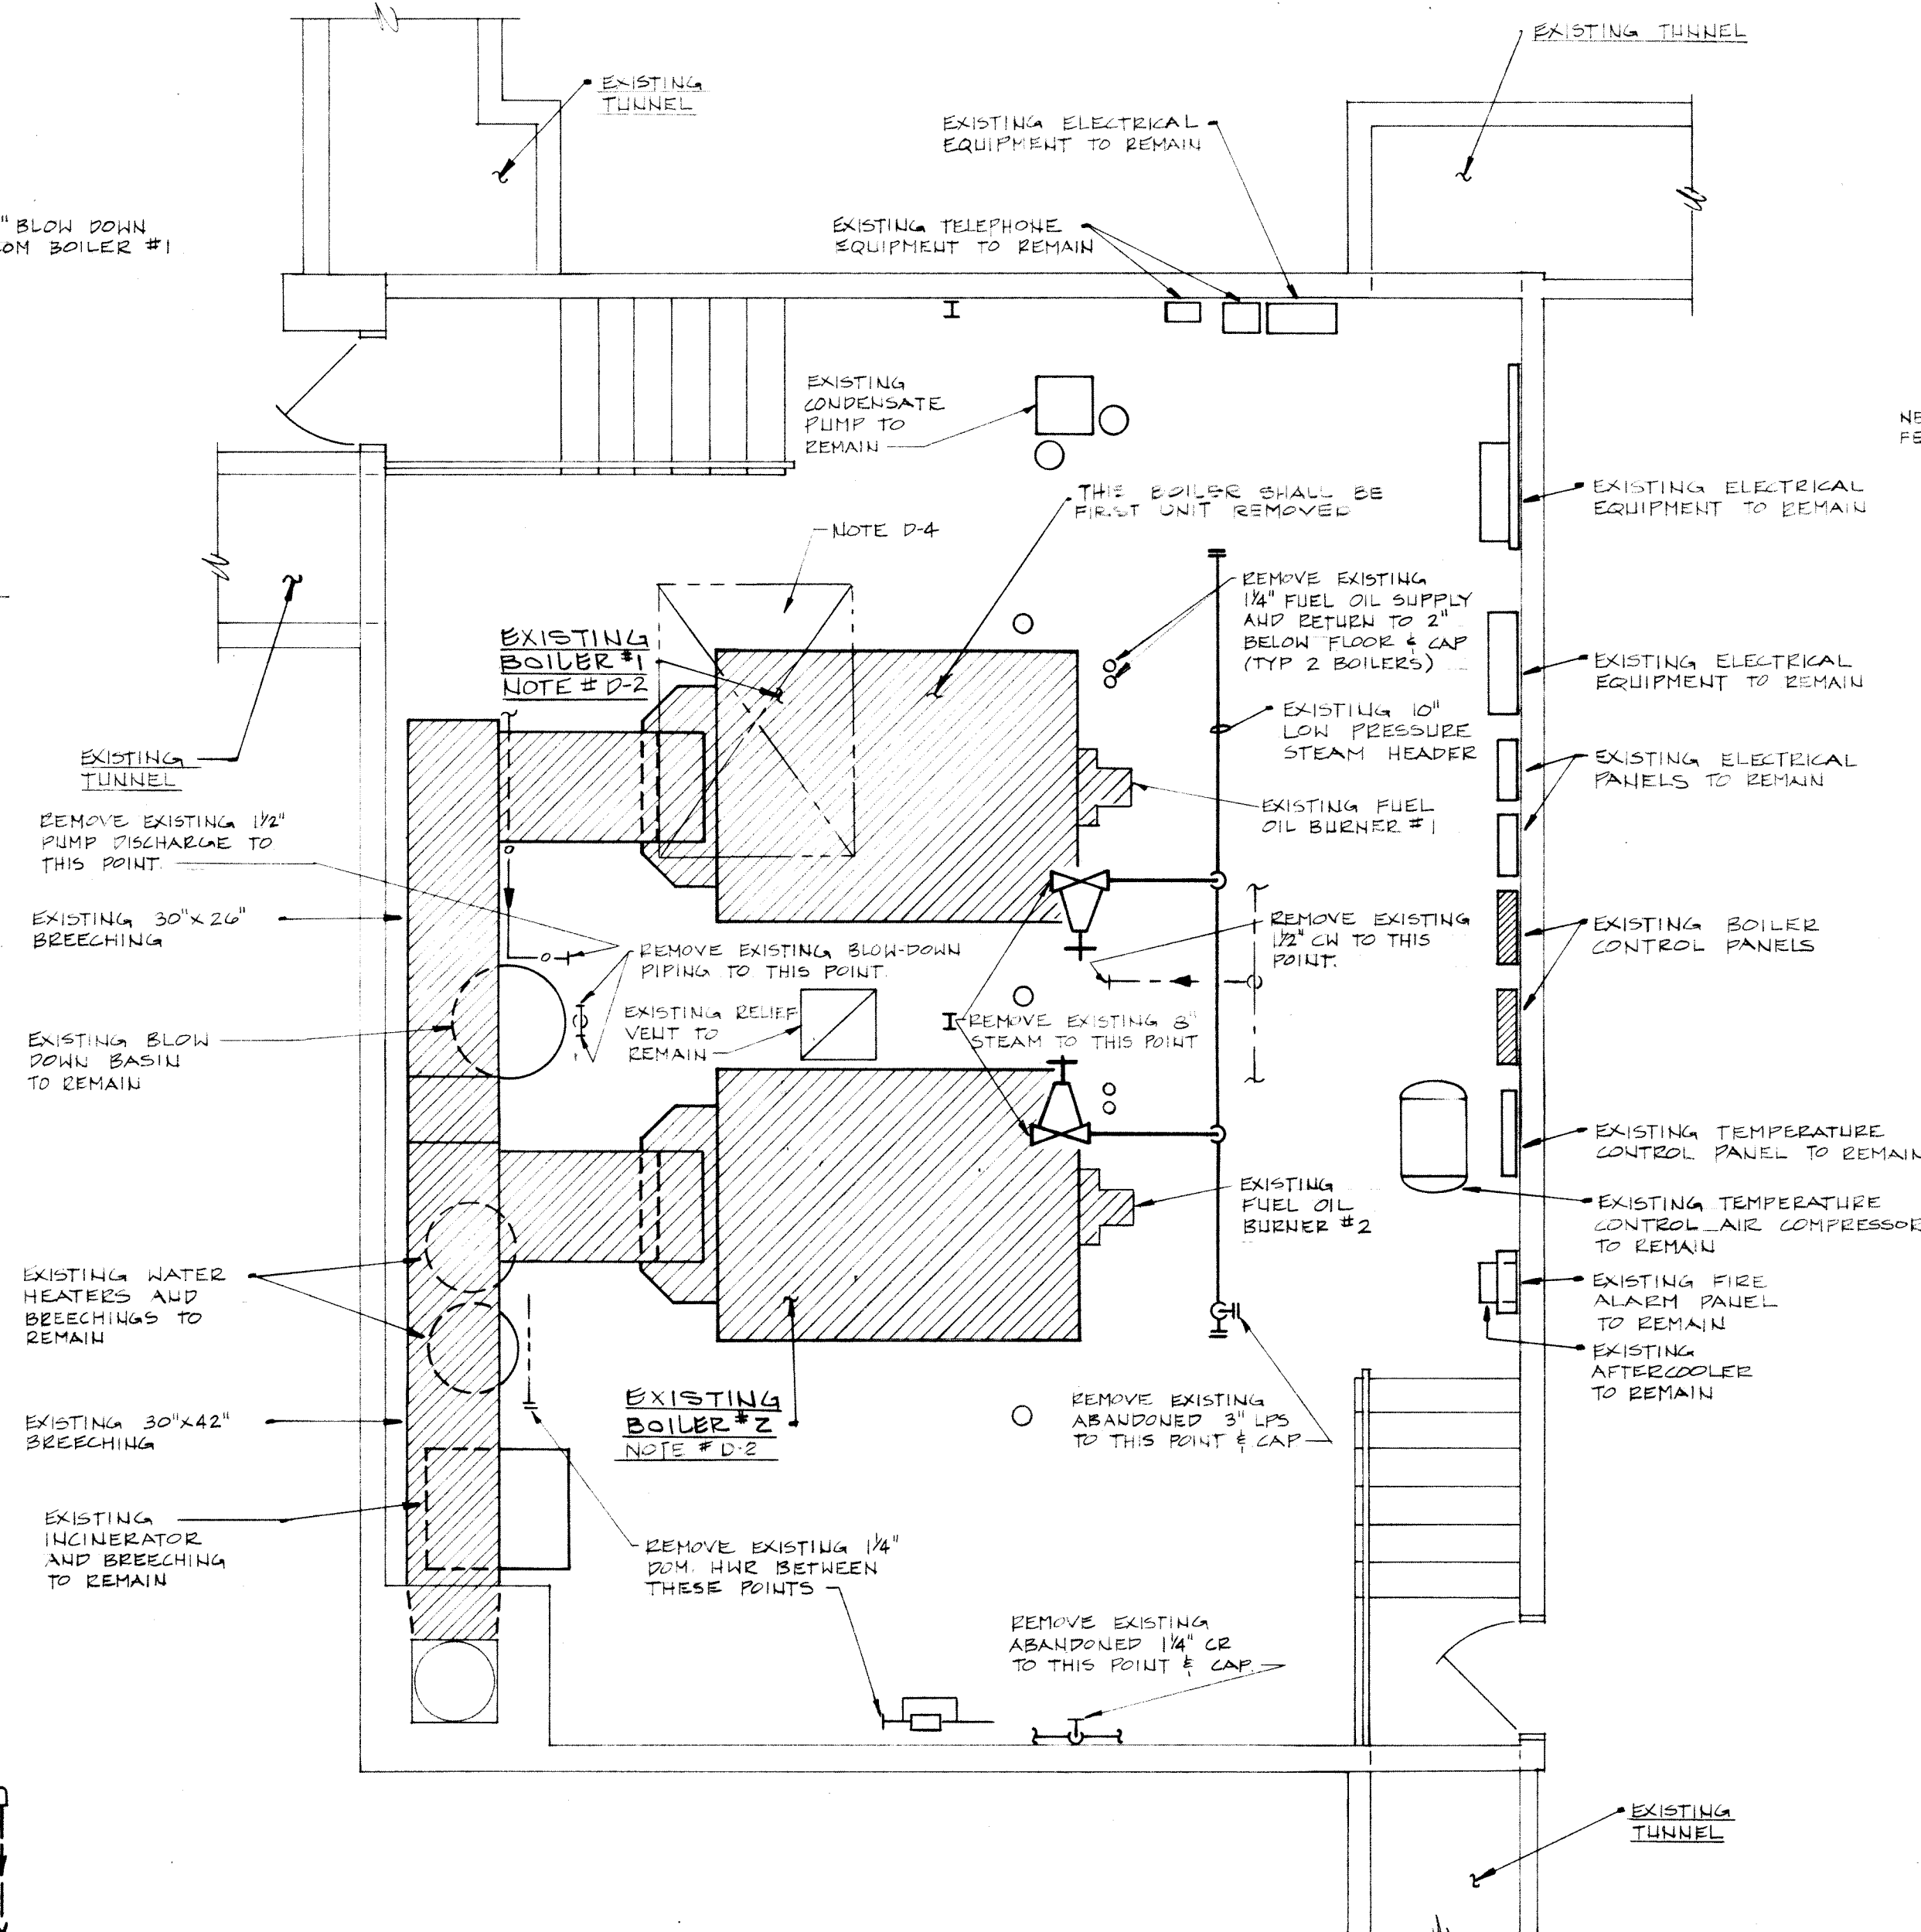




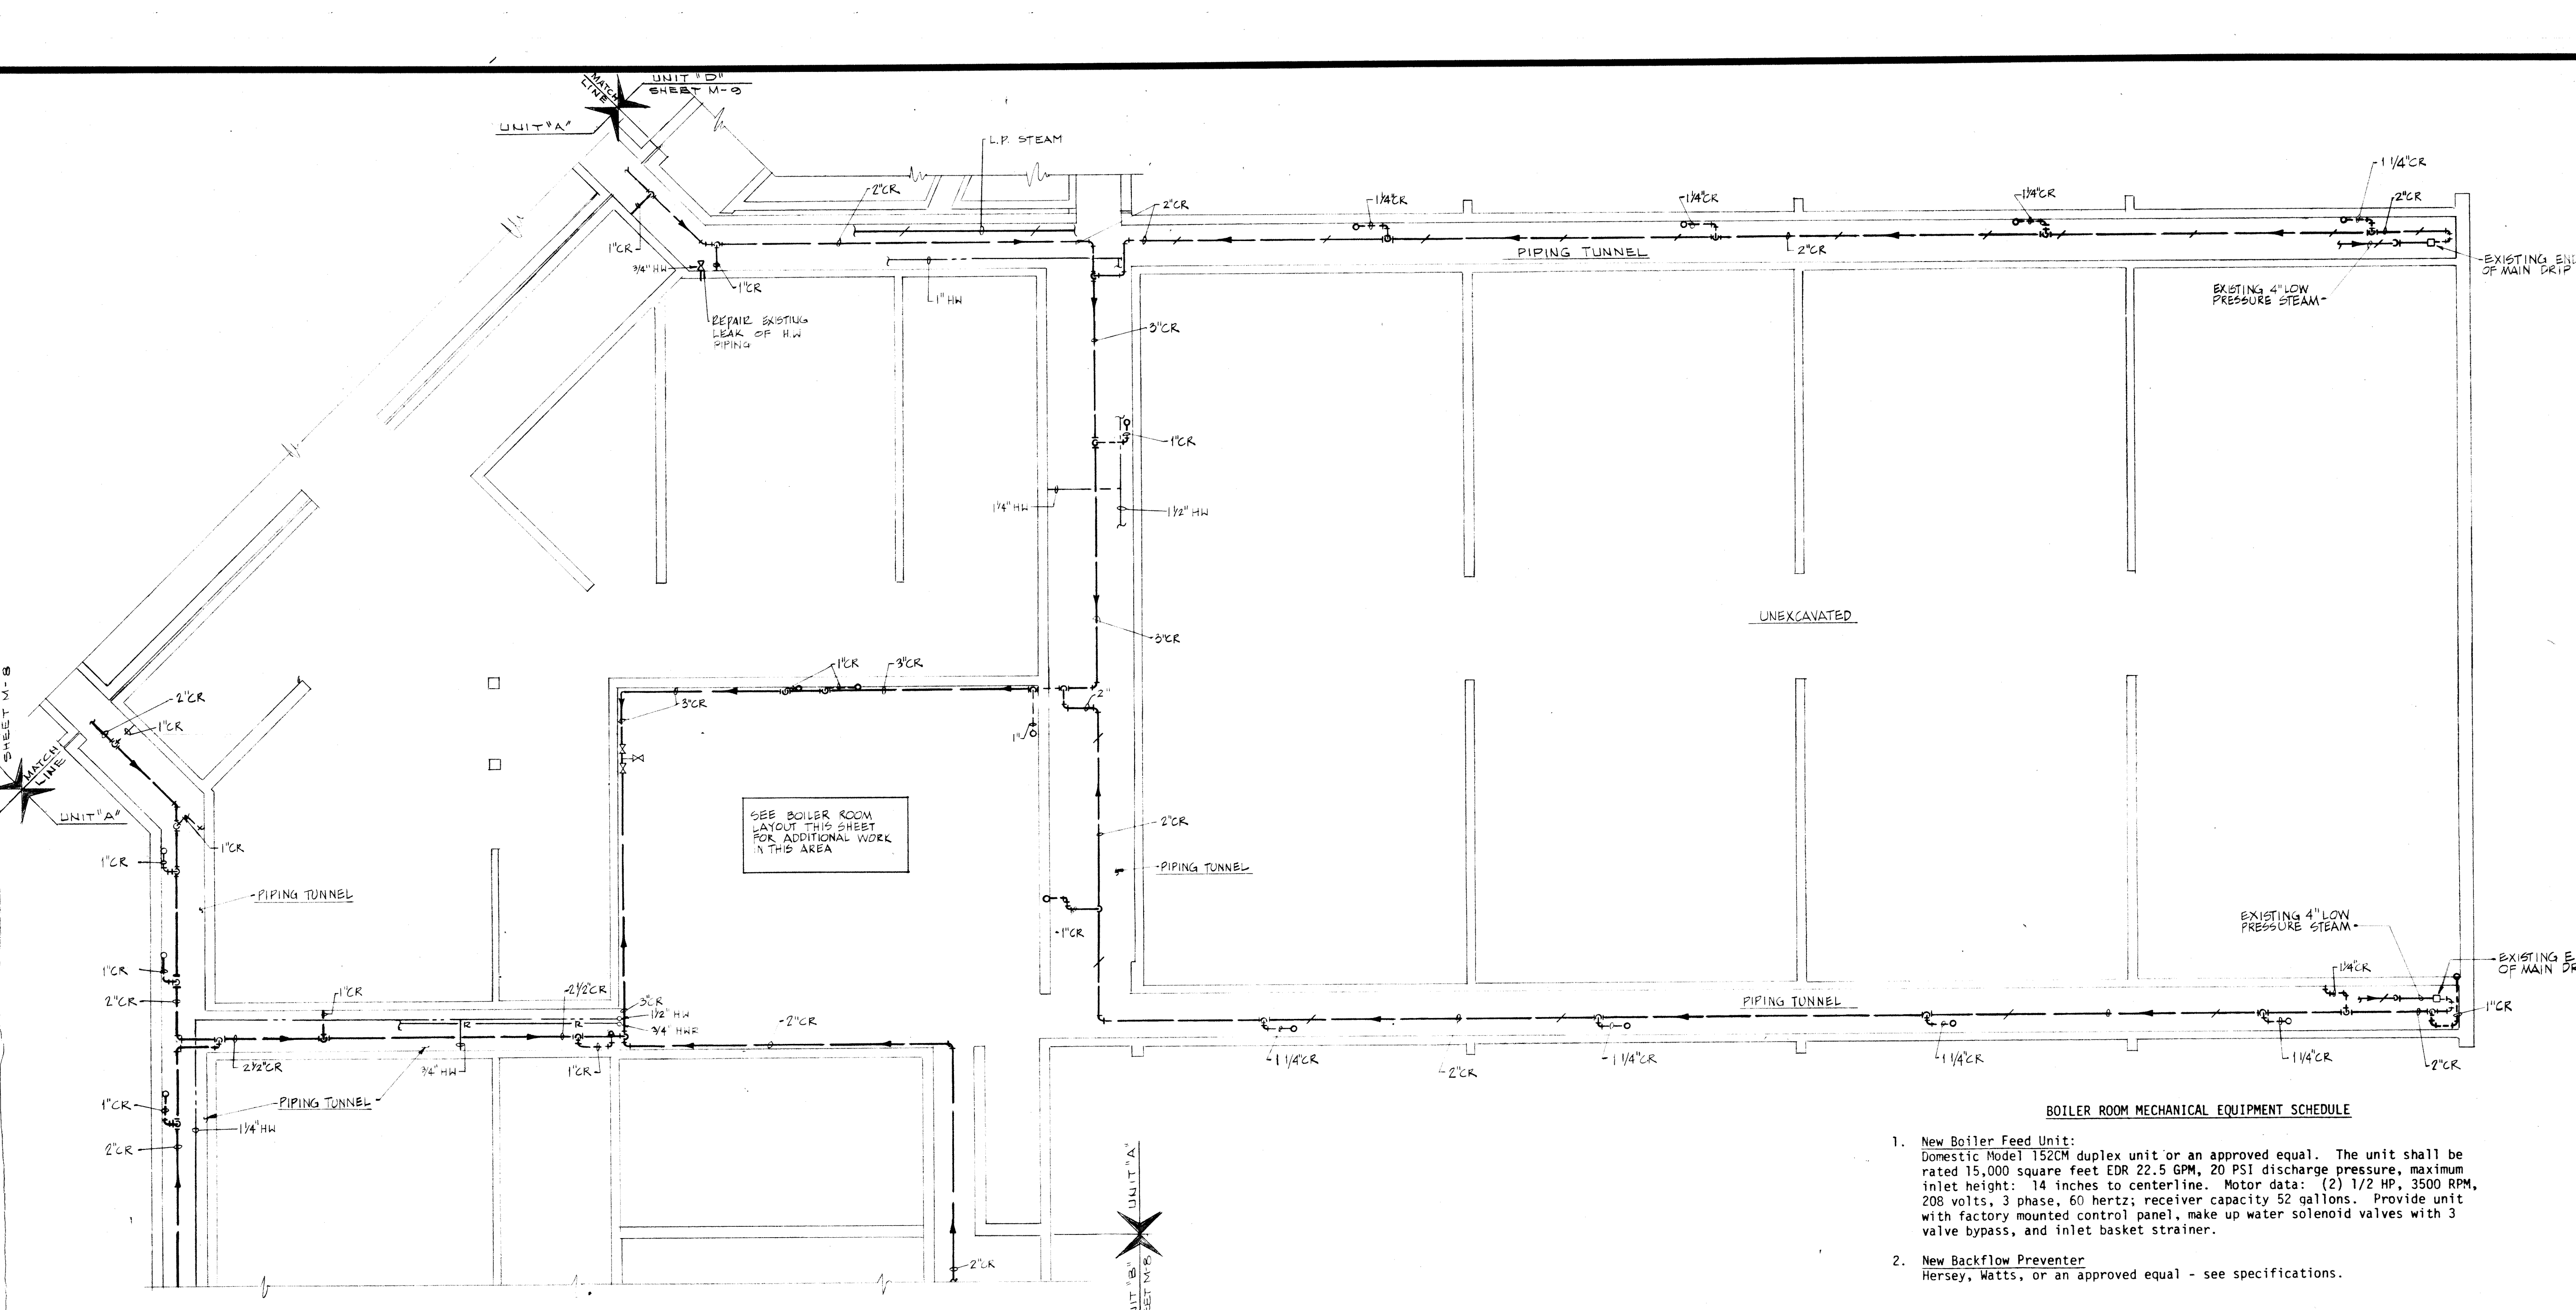


- ### PLAN NOTES
1. All piping shown is existing and to be insulated as shown in the specifications unless otherwise noted.
 2. The drawing shows only piping requiring work under this contract. The Contractor shall verify location of additional piping etc., in the areas of work which possibly might effect the performance of his works and notify the Engineer prior to proceeding with the work.
 3. Any of existing ferrous or non-ferrous piping, hangers, etc., removed from the areas of work by the Contractor shall be turned over to the Owner.
 4. All existing debris and debris created by this contract in the work areas shall be immediately removed from the job site.
 5. Provide pipe label information and flow direction arrows on all existing or new piping in the tunnels. Painting is not required.
 6. Refasten all existing loose insulation on steam mains in piping tunnels.


- ### BOILER ROOM NOTES
1. All work shown is new and by the Contractor unless otherwise noted.
 2. Contractor shall verify all existing conditions at the job site.
 3. 24" x 30" opposed blade motorized combustion air damper by Temperature Control Contractor. Damper shall be controlled by a relay furnished by the burner supplier in the Heating System burner control cabinet. Contractor shall furnish remote wall switch to override relay for summer ventilation.
 4. All valves, thermometers, gauges, feeders, fittings, etc., noted on boilers, and pumps, are typical for all boilers and pumps.
 5. All existing and new overhead gate valves on supply heating mains, 4" and larger, and over 8'-0" above finished floor shall be chain operated.
 6. All horizontal piping within the boiler room shall be suspended on rubber-in-shear hangers (see specifications).
 7. All existing steam, domestic hot and cold water piping, and domestic hot water storage tank within the boiler room where insulation is missing, loose, or damaged shall be reinsulated as per specifications unless otherwise noted.
 8. Contractor shall paint all wall and ceiling surfaces in the boiler room including doors and steel stairs. Colors to be as selected by Owner. Paint all new and existing piping, pipe hangers, supports, tanks, receivers, fuel oil pumps, etc. Piping, tanks and pumps shall be color coded and piping identified as per specifications. Electrical conduit and temperature control tubing shall be painted to match walls. Electrical panels and new equipment shall not be painted.
 9. Roof in this area shall be removed, opening framed, and louvered penthouse and curb installed as detailed on this sheet and specified.
 10. Roof in this area shall be installed, chimney flashed and counterflashed by Hinshaw Roofing as specified.
 11. 30" x 48" opposed blade relief air damper by Temperature Control Contractor. Damper to be controlled by wall mounted switch.
 12. Existing ferrous and non-ferrous piping, valves and fittings, vacuum pump and accumulator, etc. removed from boiler room shall be turned over to the Owner.
 13. Install existing Iron Fireman dual fuel burner, control panel and gas train removed from Crestview Elementary School on Boiler #1 combustion chamber. Coordinate mounting with boiler manufacturer. Modify existing or provide new front plate, refractory, etc. as required for complete installation. Reconnect fuel oil gas and electric services.
 14. Contractor shall patch and repair existing chimney masonry within the Boiler Room as required and directed by the Engineer.
 15. All cost of this work, including that of Hinshaw Roofing, shall be included in this Contractor's price.

- ### BOILER ROOM MECHANICAL EQUIPMENT SCHEDULE
1. New Boiler Feed Unit:
Domestic Model 152CM duplex unit or an approved equal. The unit shall be rated 15,000 square feet EDR 22.5 GPM, 20 PSI discharge pressure, maximum inlet height: 14 inches to centerline. Motor data: (2) 1/2 HP, 3500 RPM, 208 volts, 3 phase, 60 hertz; receiver capacity 52 gallons. Provide unit with factory mounted control panel, make up water solenoid valves with 3 valve bypass, and inlet basket strainer.
 2. New Backflow Preventer:
Hersey, Watts, or an approved equal - see specifications.

UNIT 'A' MECHANICAL FOUNDATION PLAN
SCALE 1/8" = 1'-0"

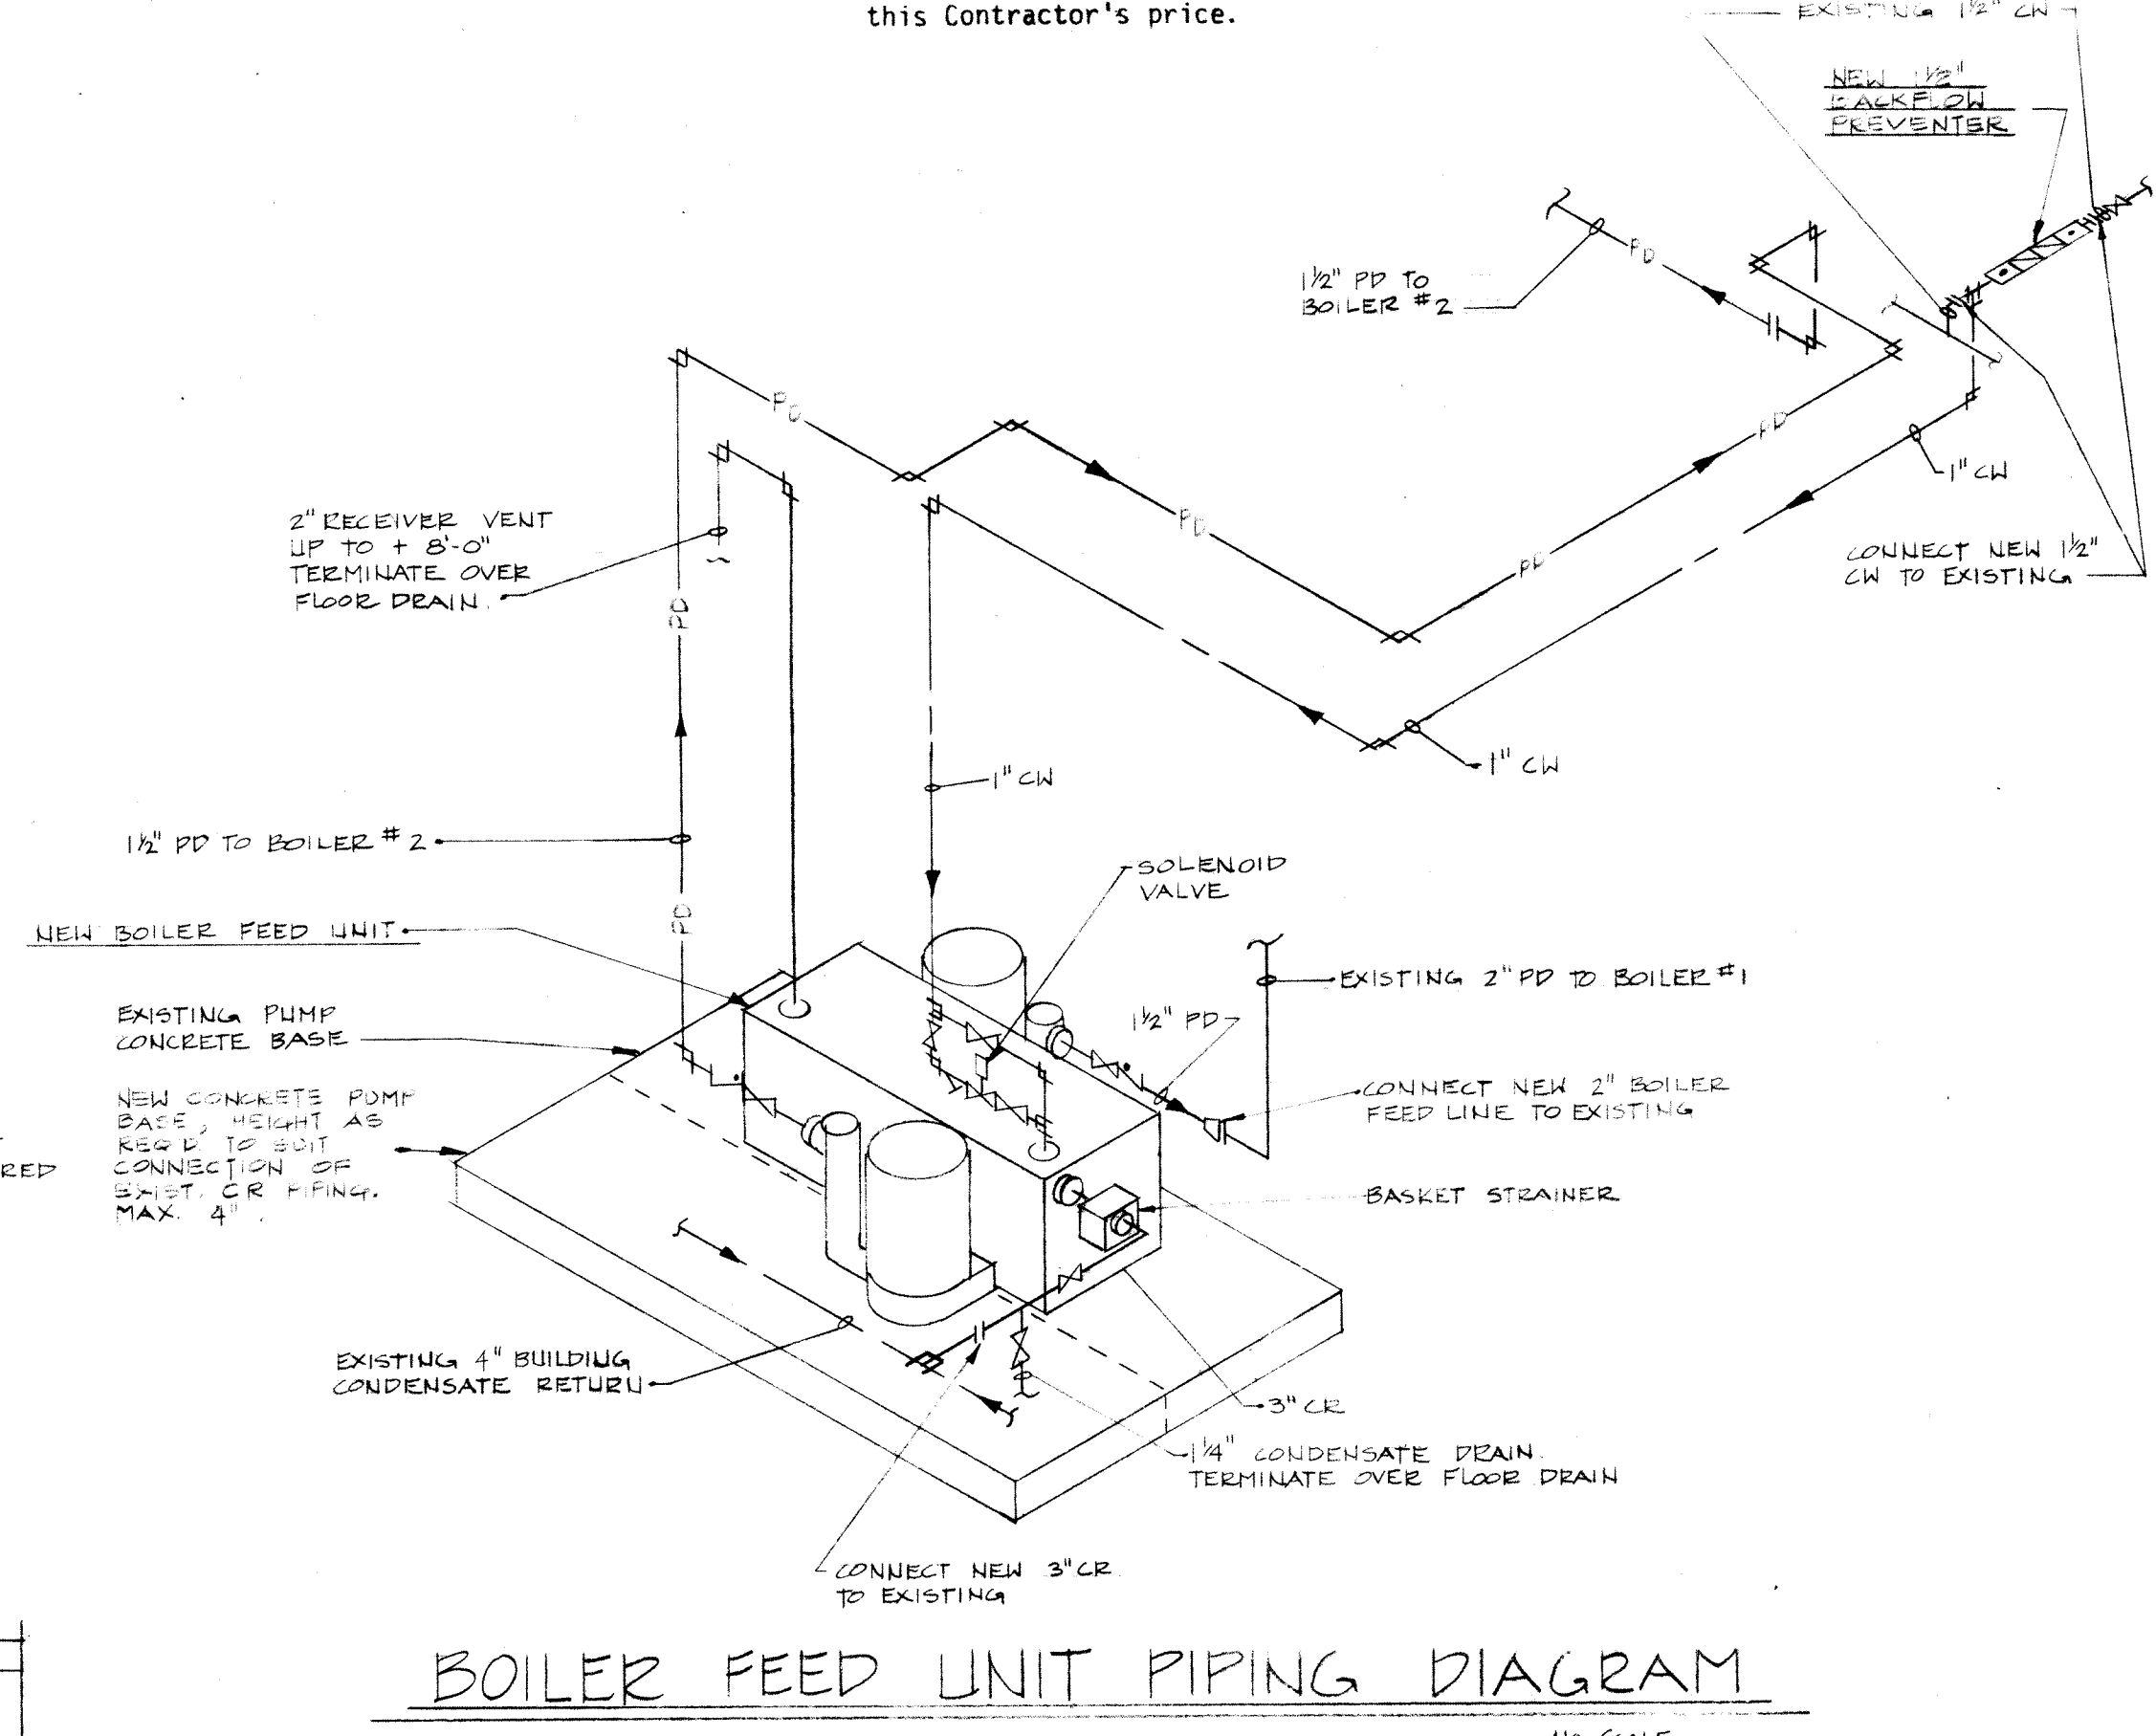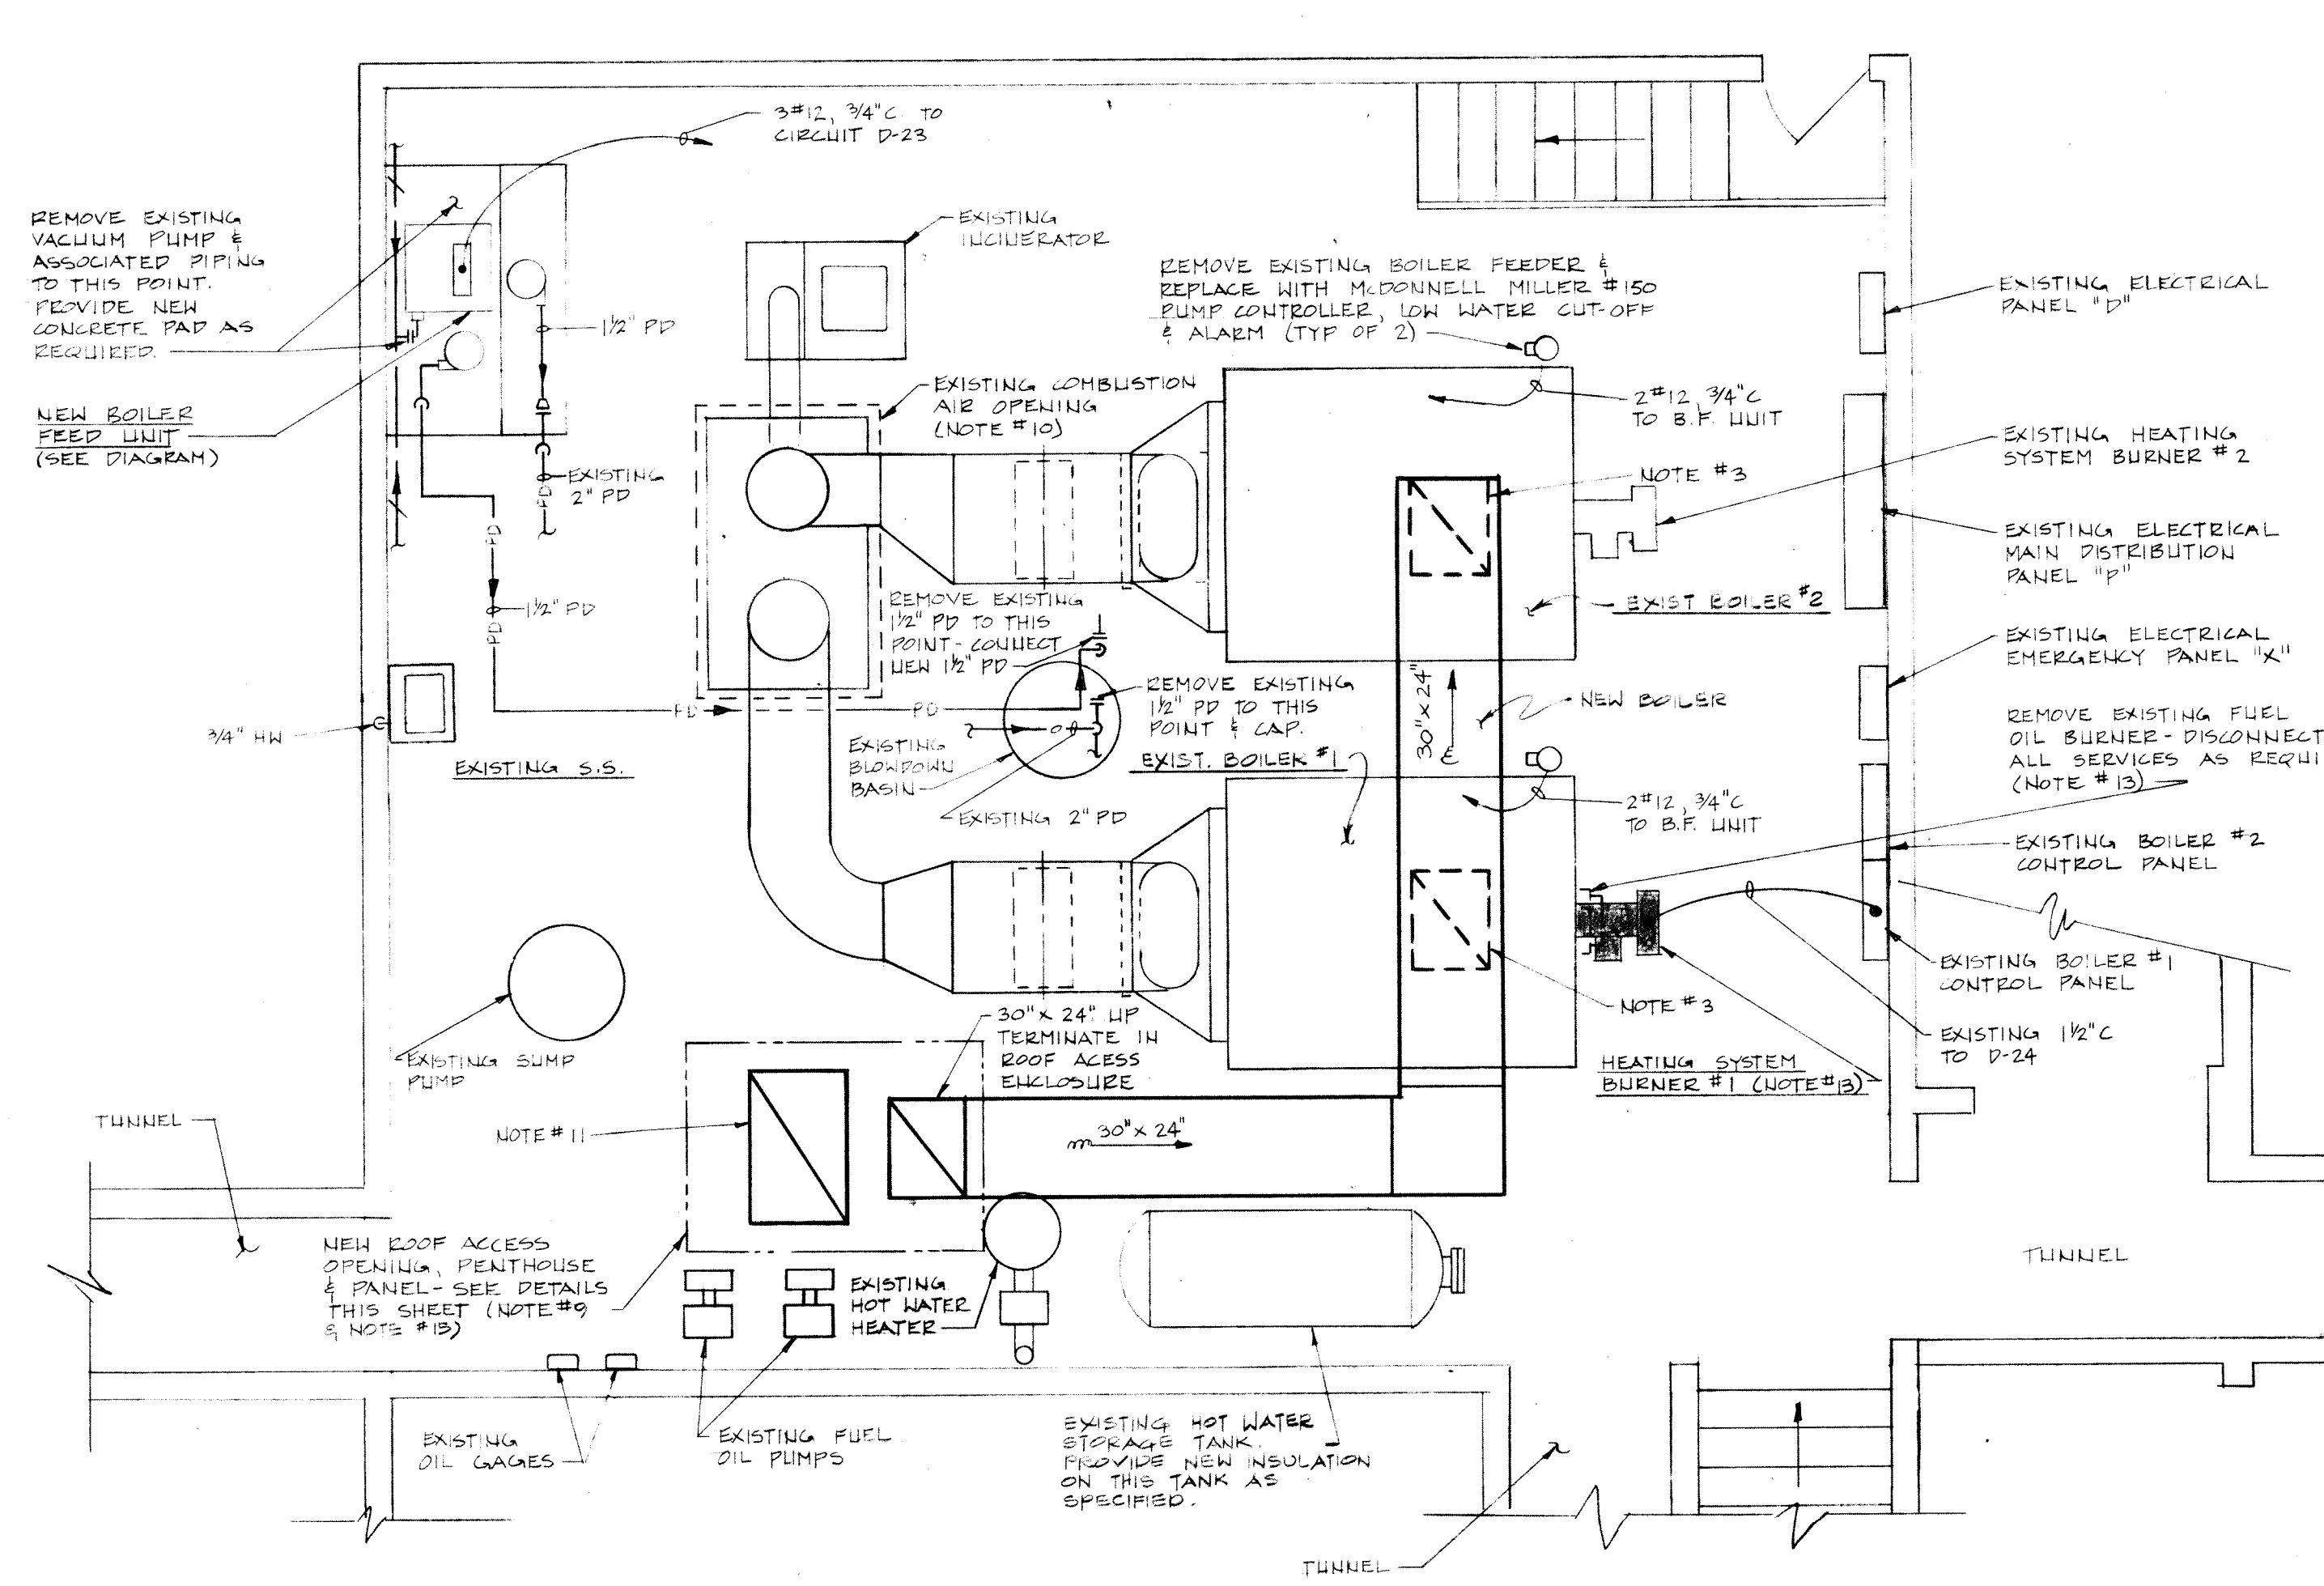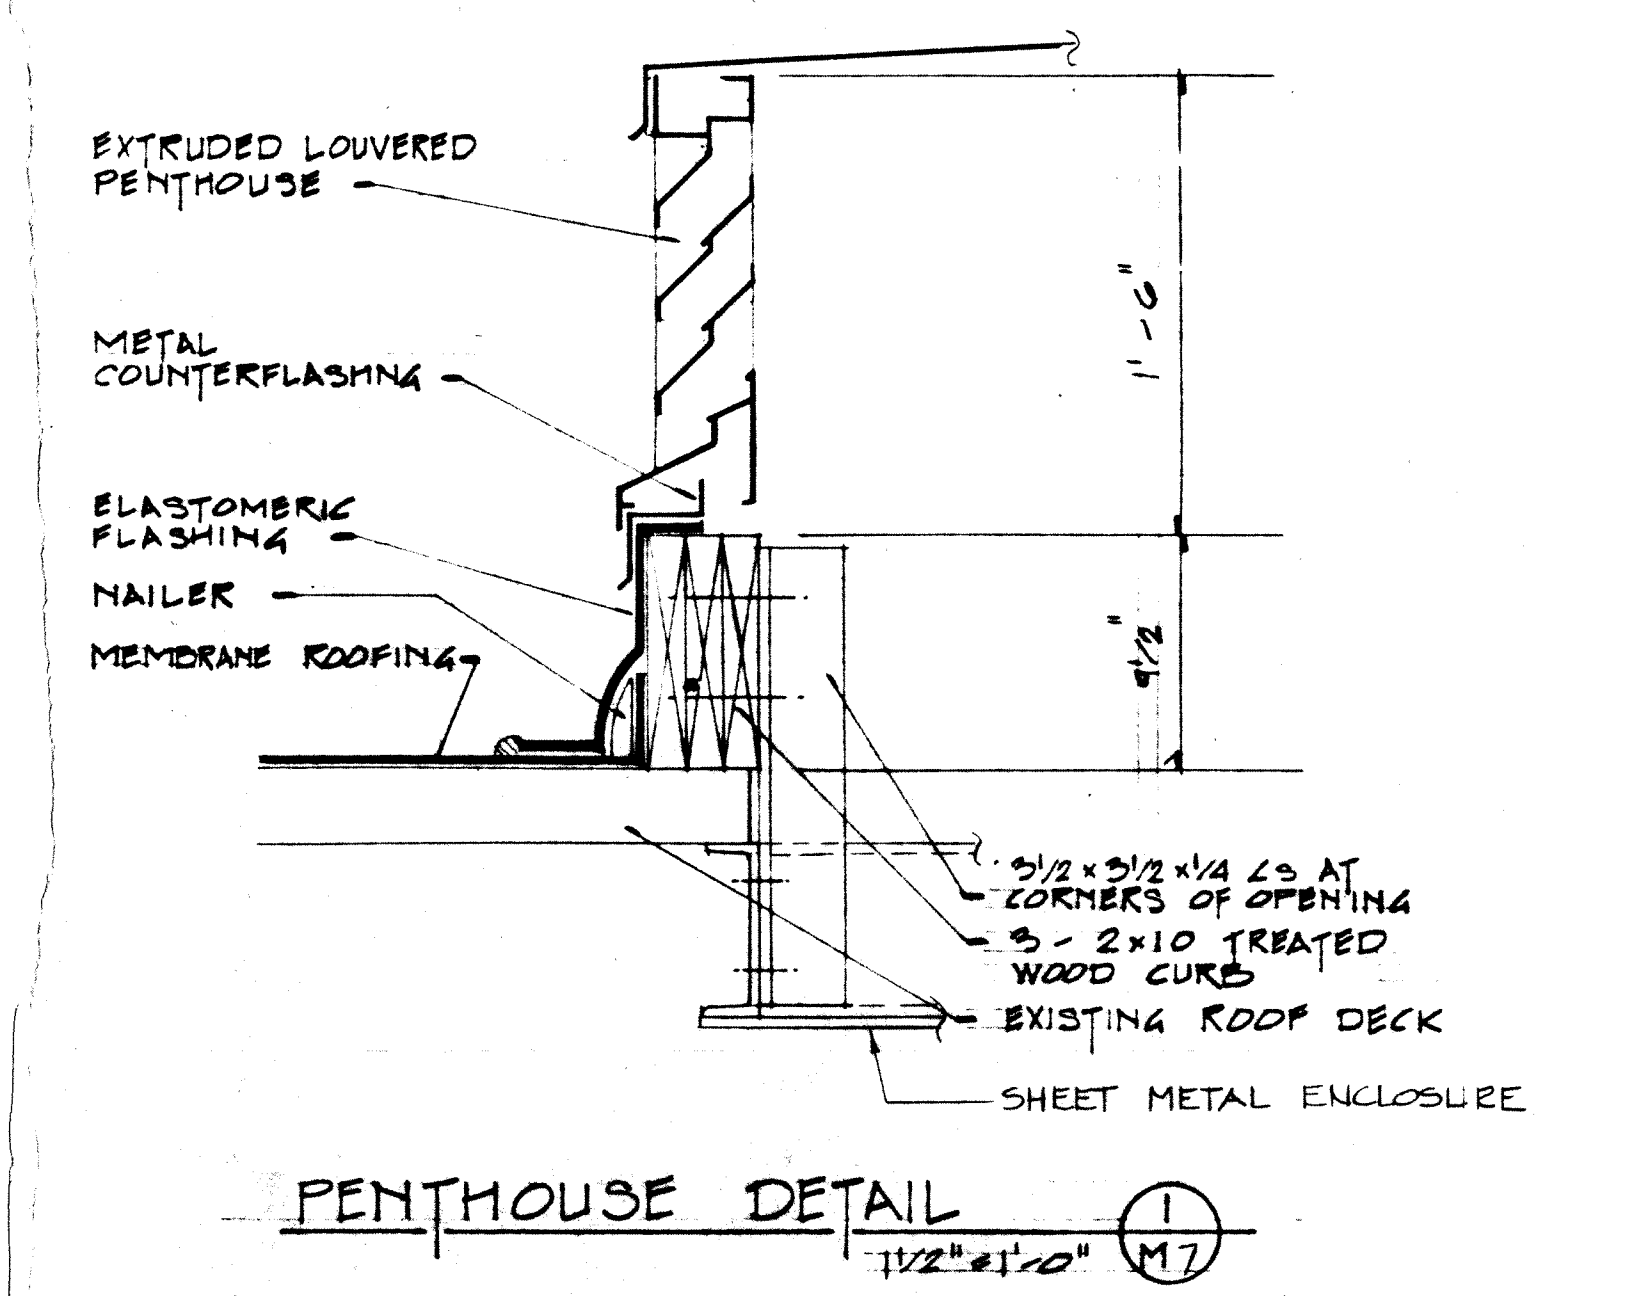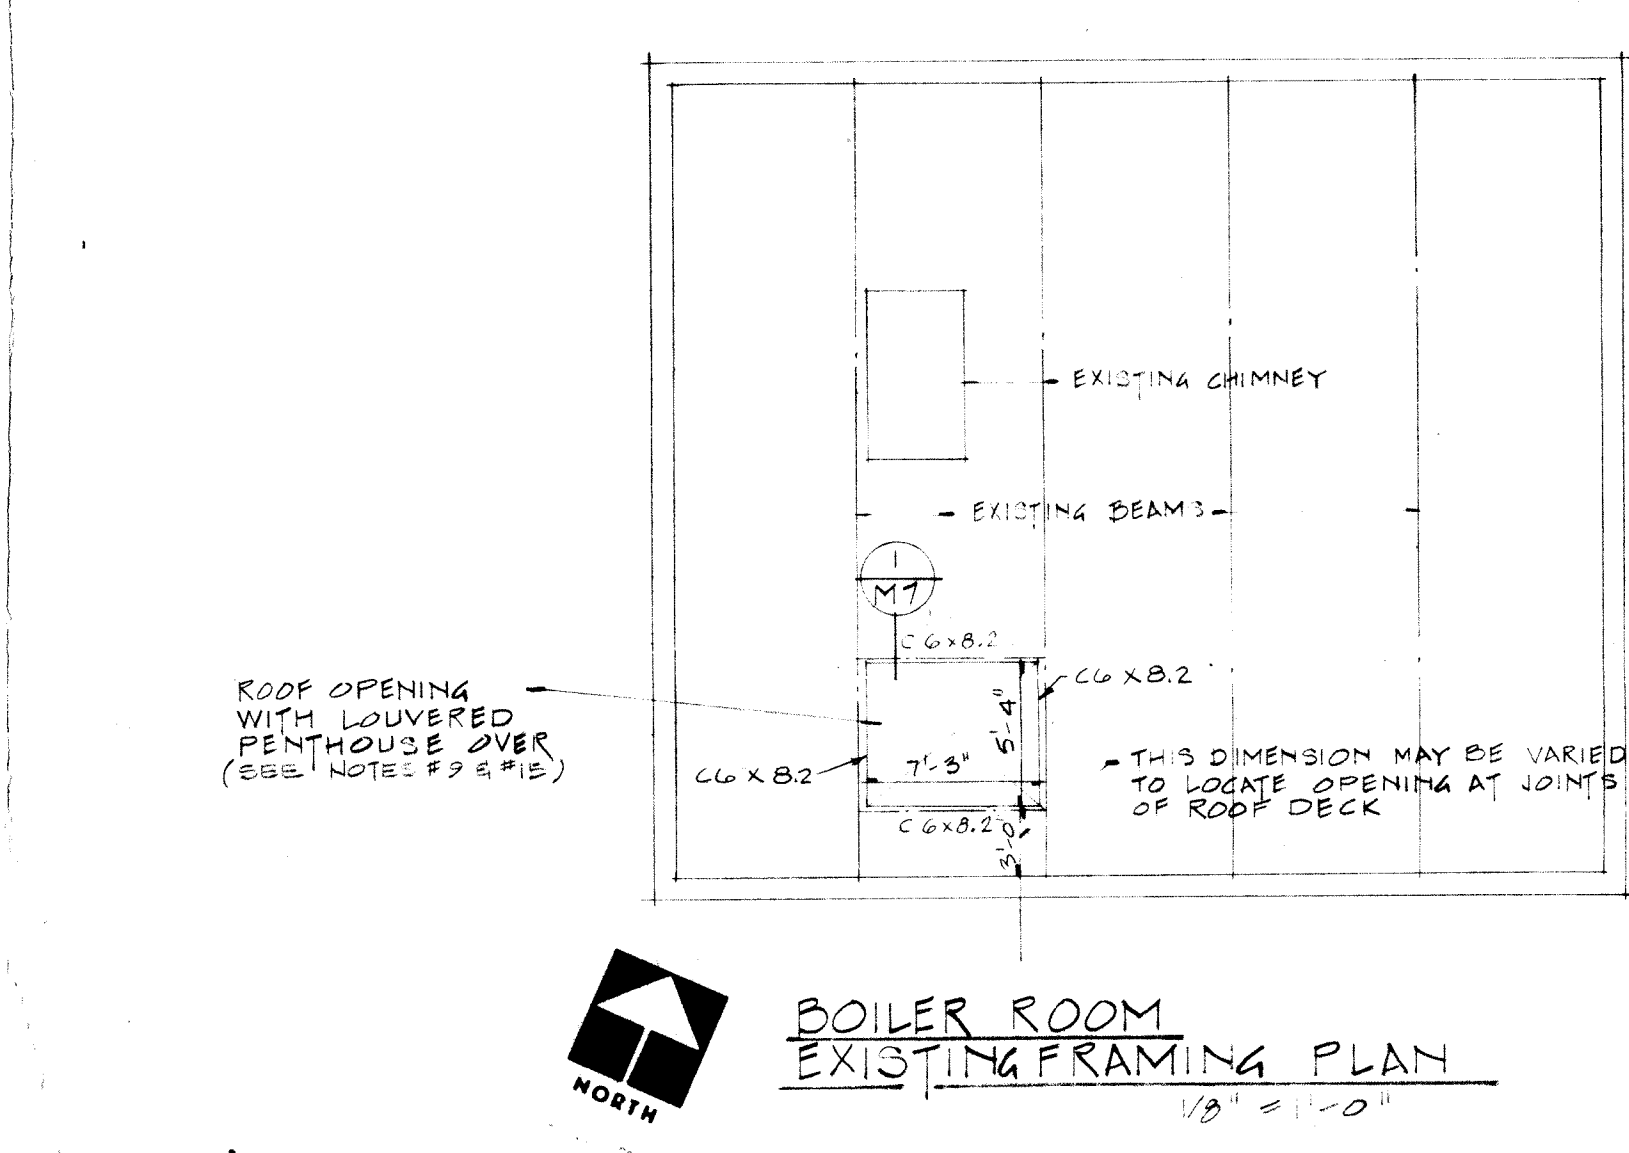

MECHANICAL BOILER ROOM LAYOUT
SCALE: 1/8" = 1'-0"

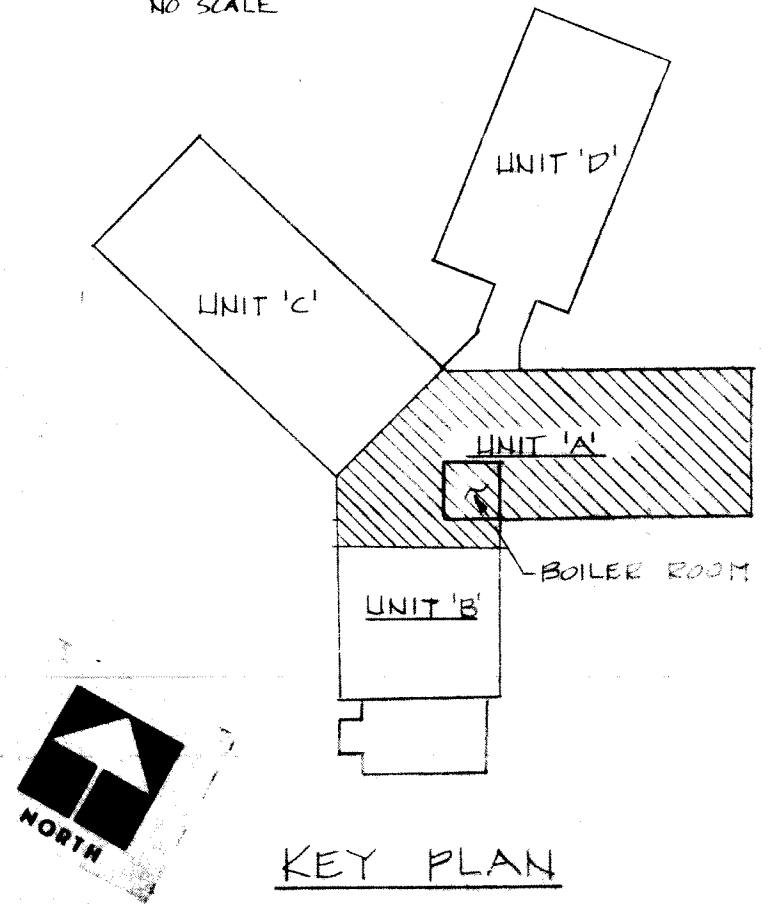

WRIGHT PORTER & LOWE INC.
 ARCHITECTS - ENGINEERS
 INDIANAPOLIS, INDIANA

COGILL/OBERLIES & ASSOCIATES
 Consulting Engineers
 INDIANAPOLIS, INDIANA


UNIT A - TUNNEL PLAN - BOILER ROOM

METROPOLITAN SCHOOL DISTRICT
 OF LAWRENCE TOWNSHIP
 BROOK PARK ELEMENTARY SCHOOL


NO.	DATE	REVISIONS	DESCRIPTION	CONV. NO.	DATE	BY	CHECKED BY
1	8/20/01				11/20/01	DAVID BY	3/2/02
2							
3							
4							
5							

M-7
 OF 13


SHEET
 KEY PLAN

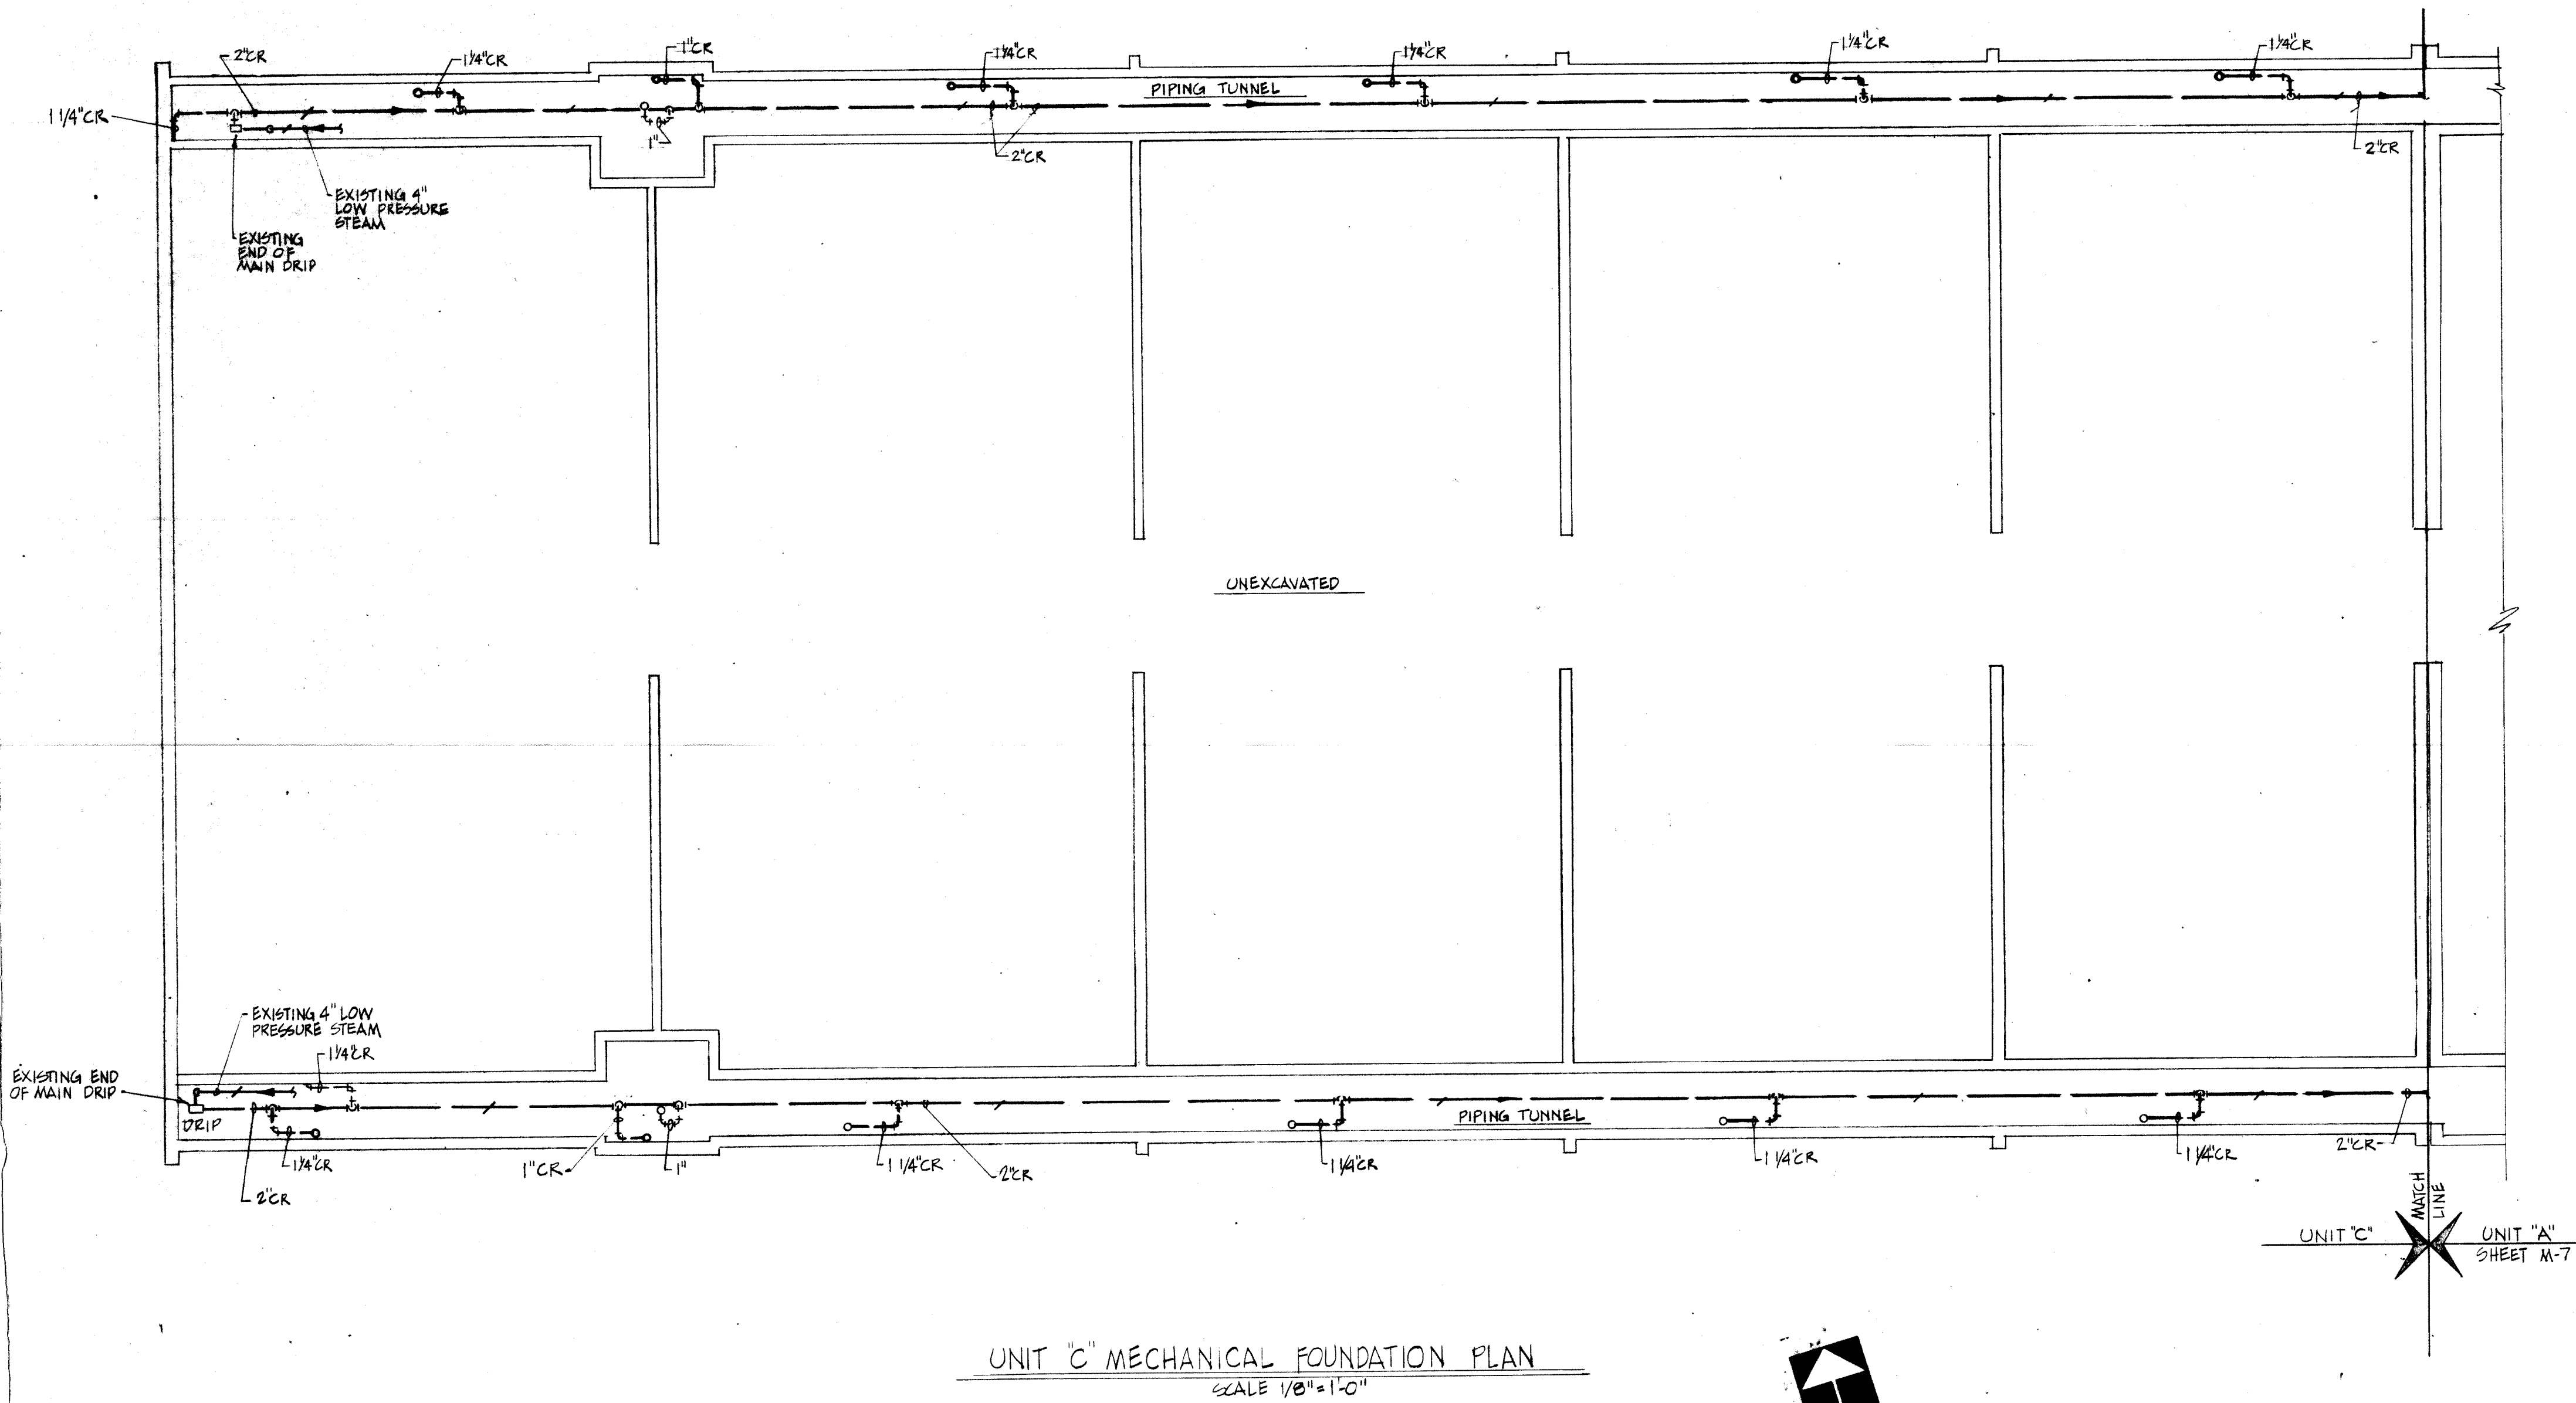

UNIT "C" MECHANICAL FOUNDATION PLAN
SCALE: 1/8"=1'-0"

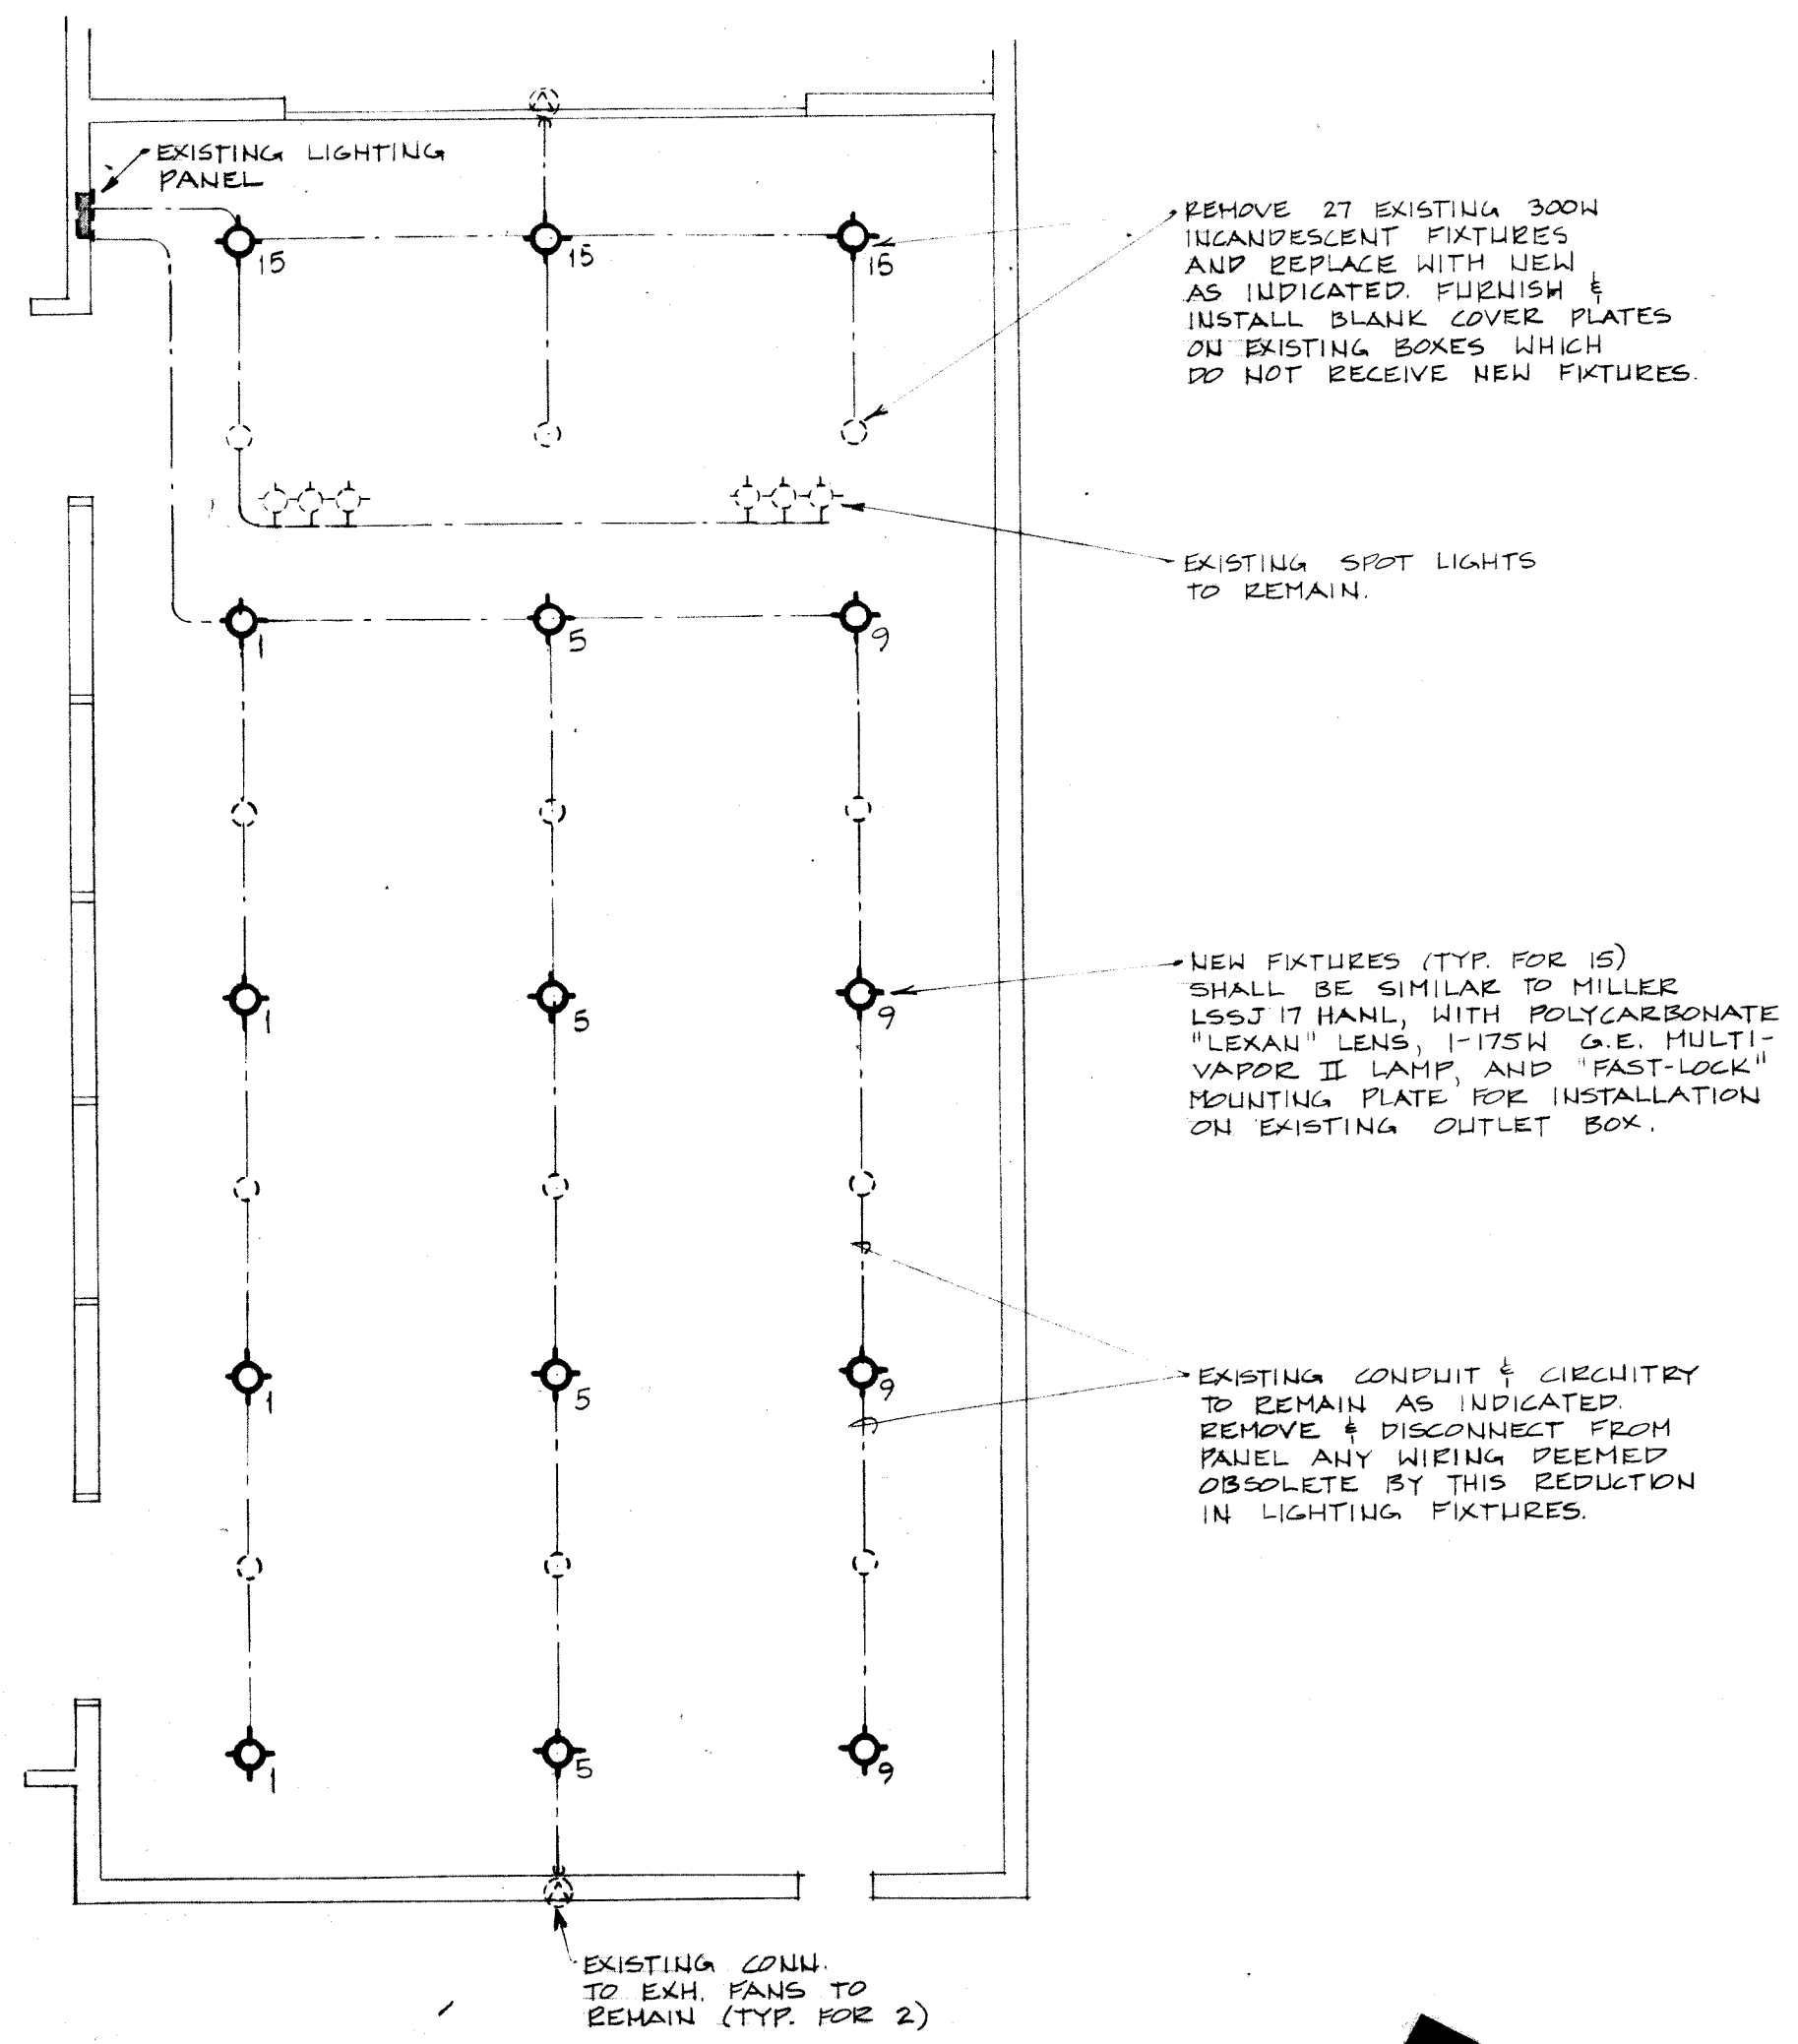


MULTI-PURPOSE ROOM - LIGHTING PLAN - UNIT 'B'
SCALE: 1/8"=1'-0"

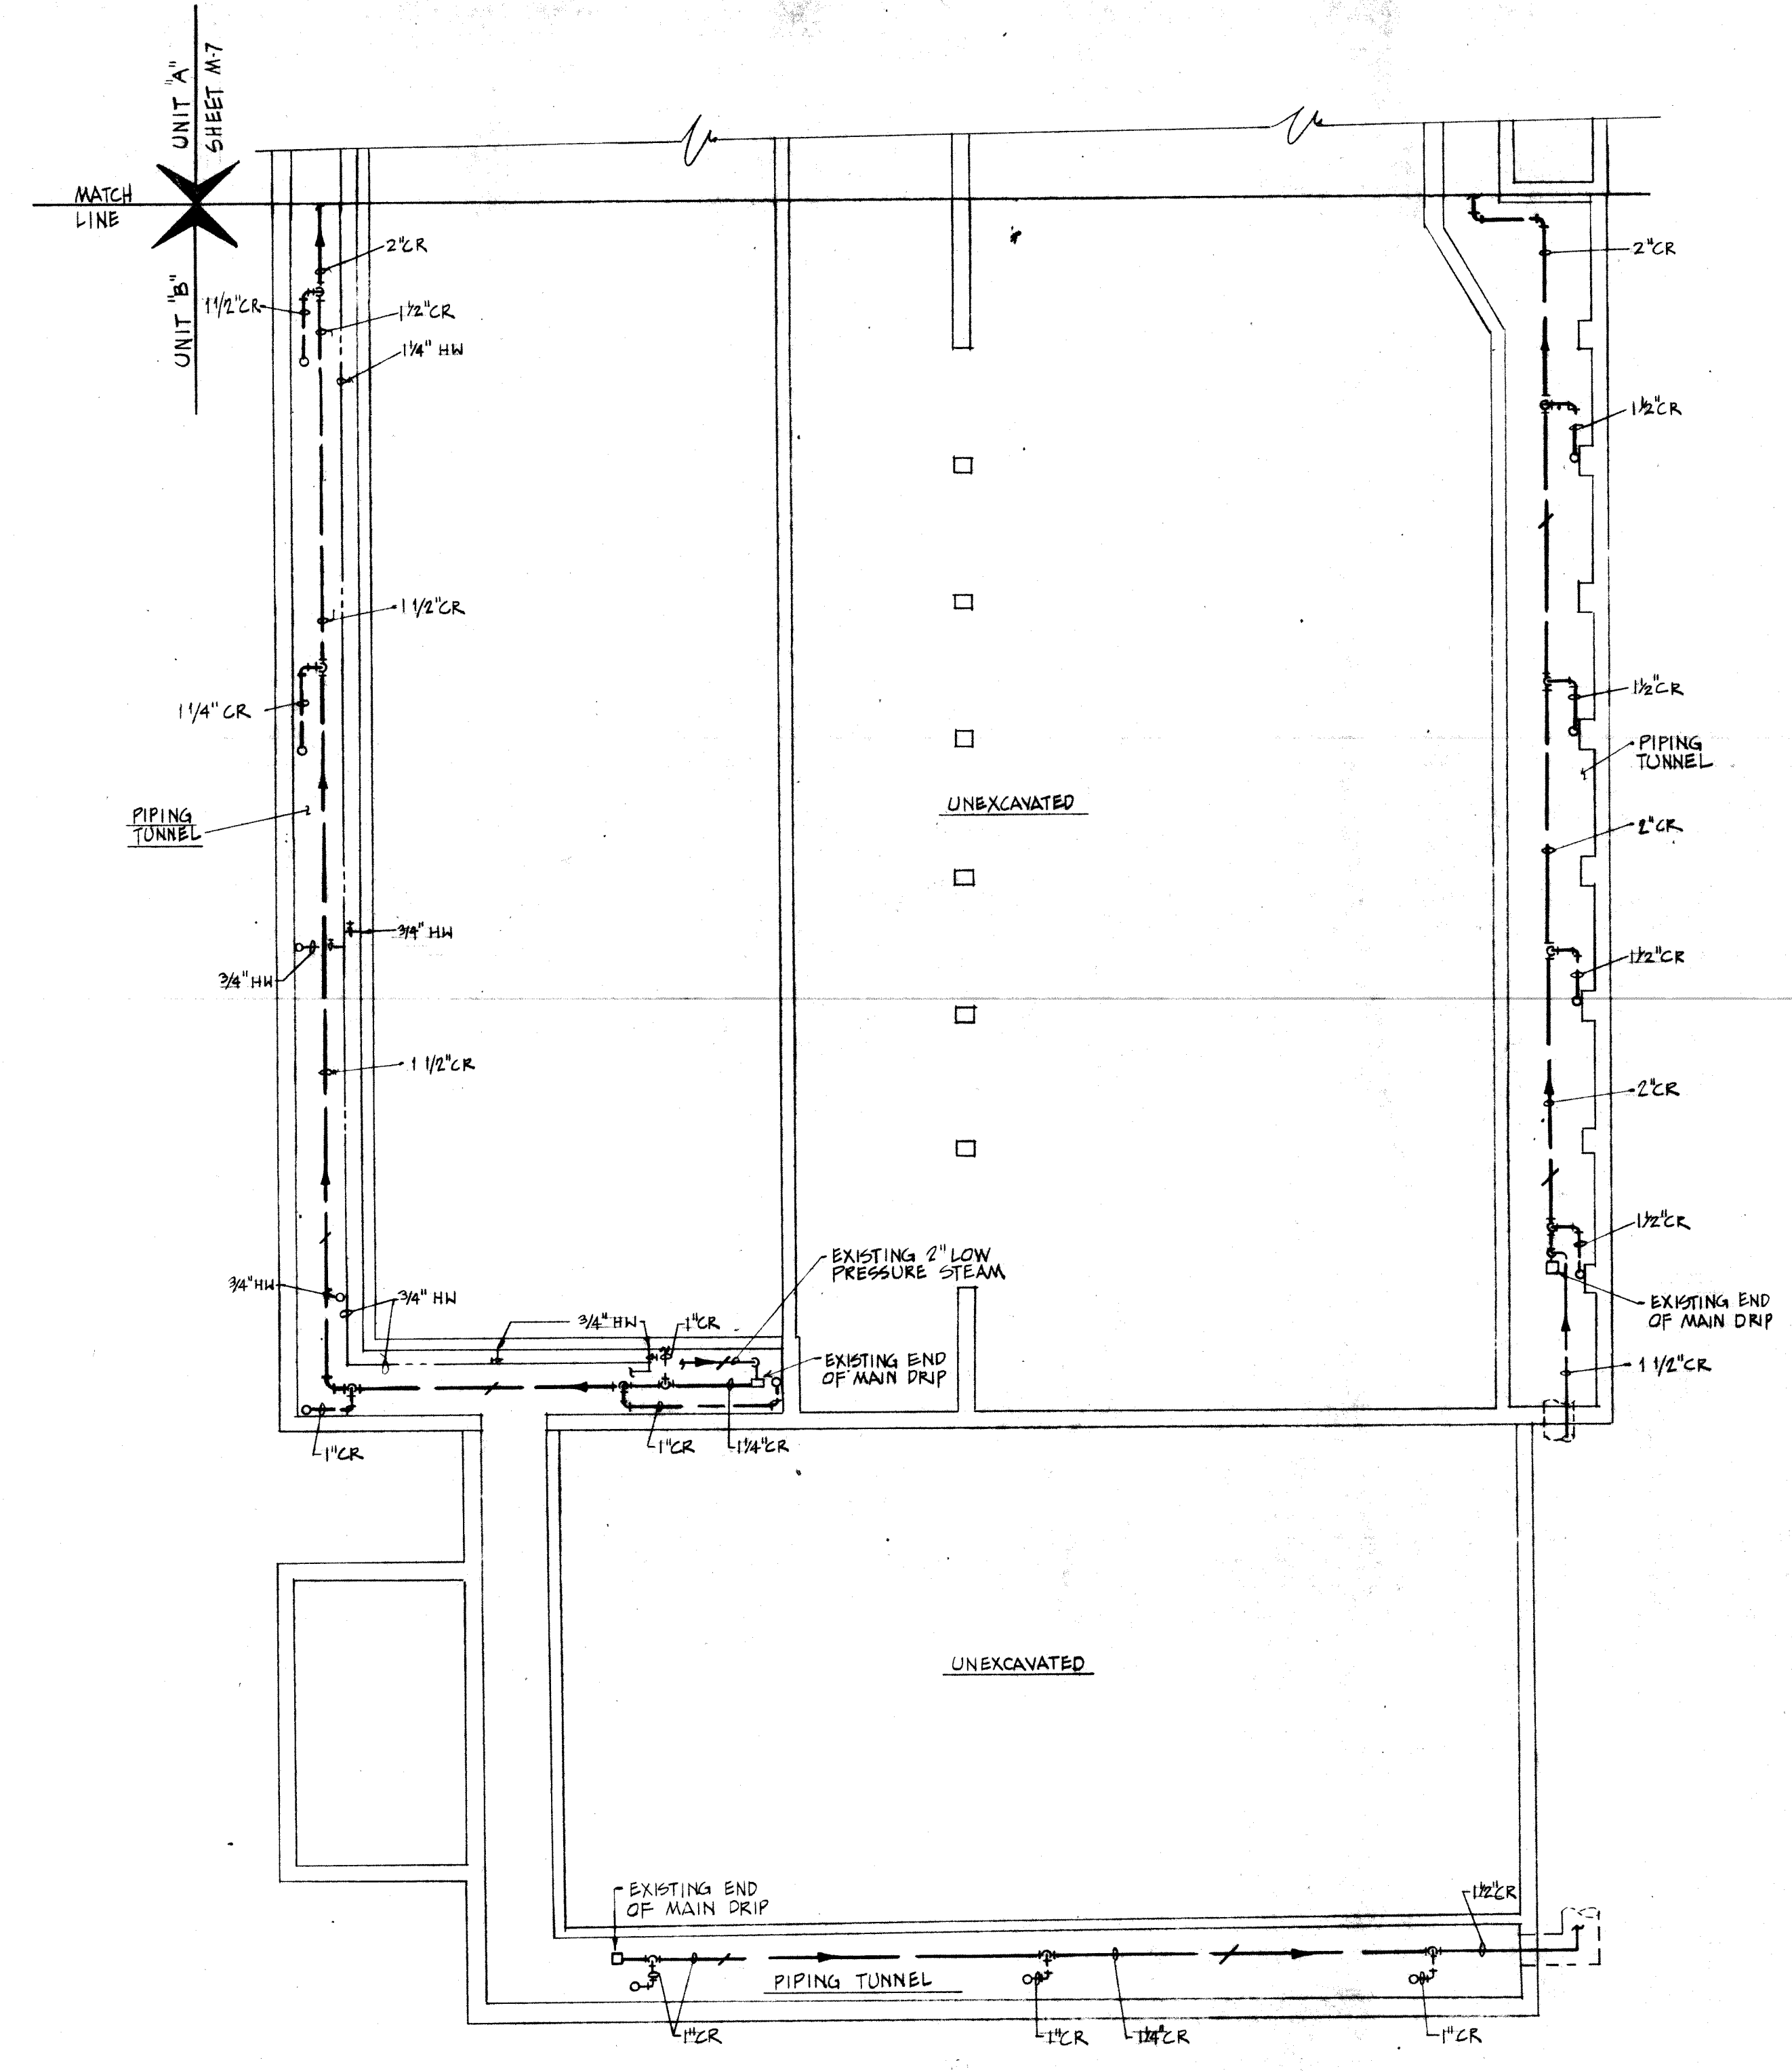

UNIT "B" MECHANICAL FOUNDATION PLAN
SCALE: 1/8"=1'-0"

PLAN NOTES

1. All piping shown is existing and to be insulated as shown in the specifications unless otherwise noted.
2. The drawing shows only piping requiring work under this contract. The Contractor shall verify location of additional piping etc., in the areas of work which possibly might effect the performance of his works and notify the Engineer prior to proceeding with the work.
3. Any of existing ferrous or non-ferrous piping, hangers, etc., removed from the areas of work by the Contractor shall be turned over to the Owner.
4. All existing debris and debris created by this contract in the work areas shall be immediately removed from the job site.
5. Provide pipe label information and flow direction arrows on all existing or new piping in the tunnels. Painting is not required.
6. Refasten all existing loose insulation on steam mains in piping tunnels.

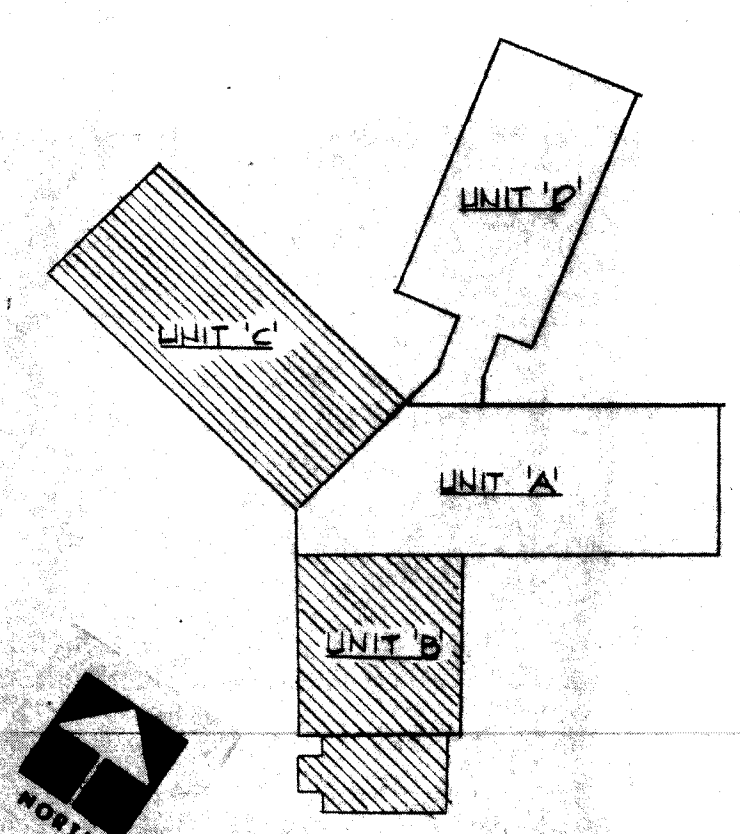

KEY PLAN

WRIGHT PORTER & LOWE INC.
ARCHITECTS - ENGINEERS
INDIANAPOLIS, INDIANA

COGILL/OBERLIES & ASSOCIATES
Consulting Engineers
INDIANAPOLIS, INDIANA

UNIT B & C - TUNNEL PLAN - GYMNASIUM

METROPOLITAN SCHOOL DISTRICT
OF LAWRENCE TOWNSHIP
BROOK PARK ELEMENTARY SCHOOL

REVISIONS		CONTRACT NO.	DATE	DATE	DRAWN BY	CHECKED BY
NO.	DESCRIPTION	6/12/01	11/30/01	3/02	EE5	EE5


REGISTERED PROFESSIONAL ENGINEER
No. 13968
State of Indiana

CERTIFIED BY
J. L. COGILL


SHEET

M.S.

OF 13

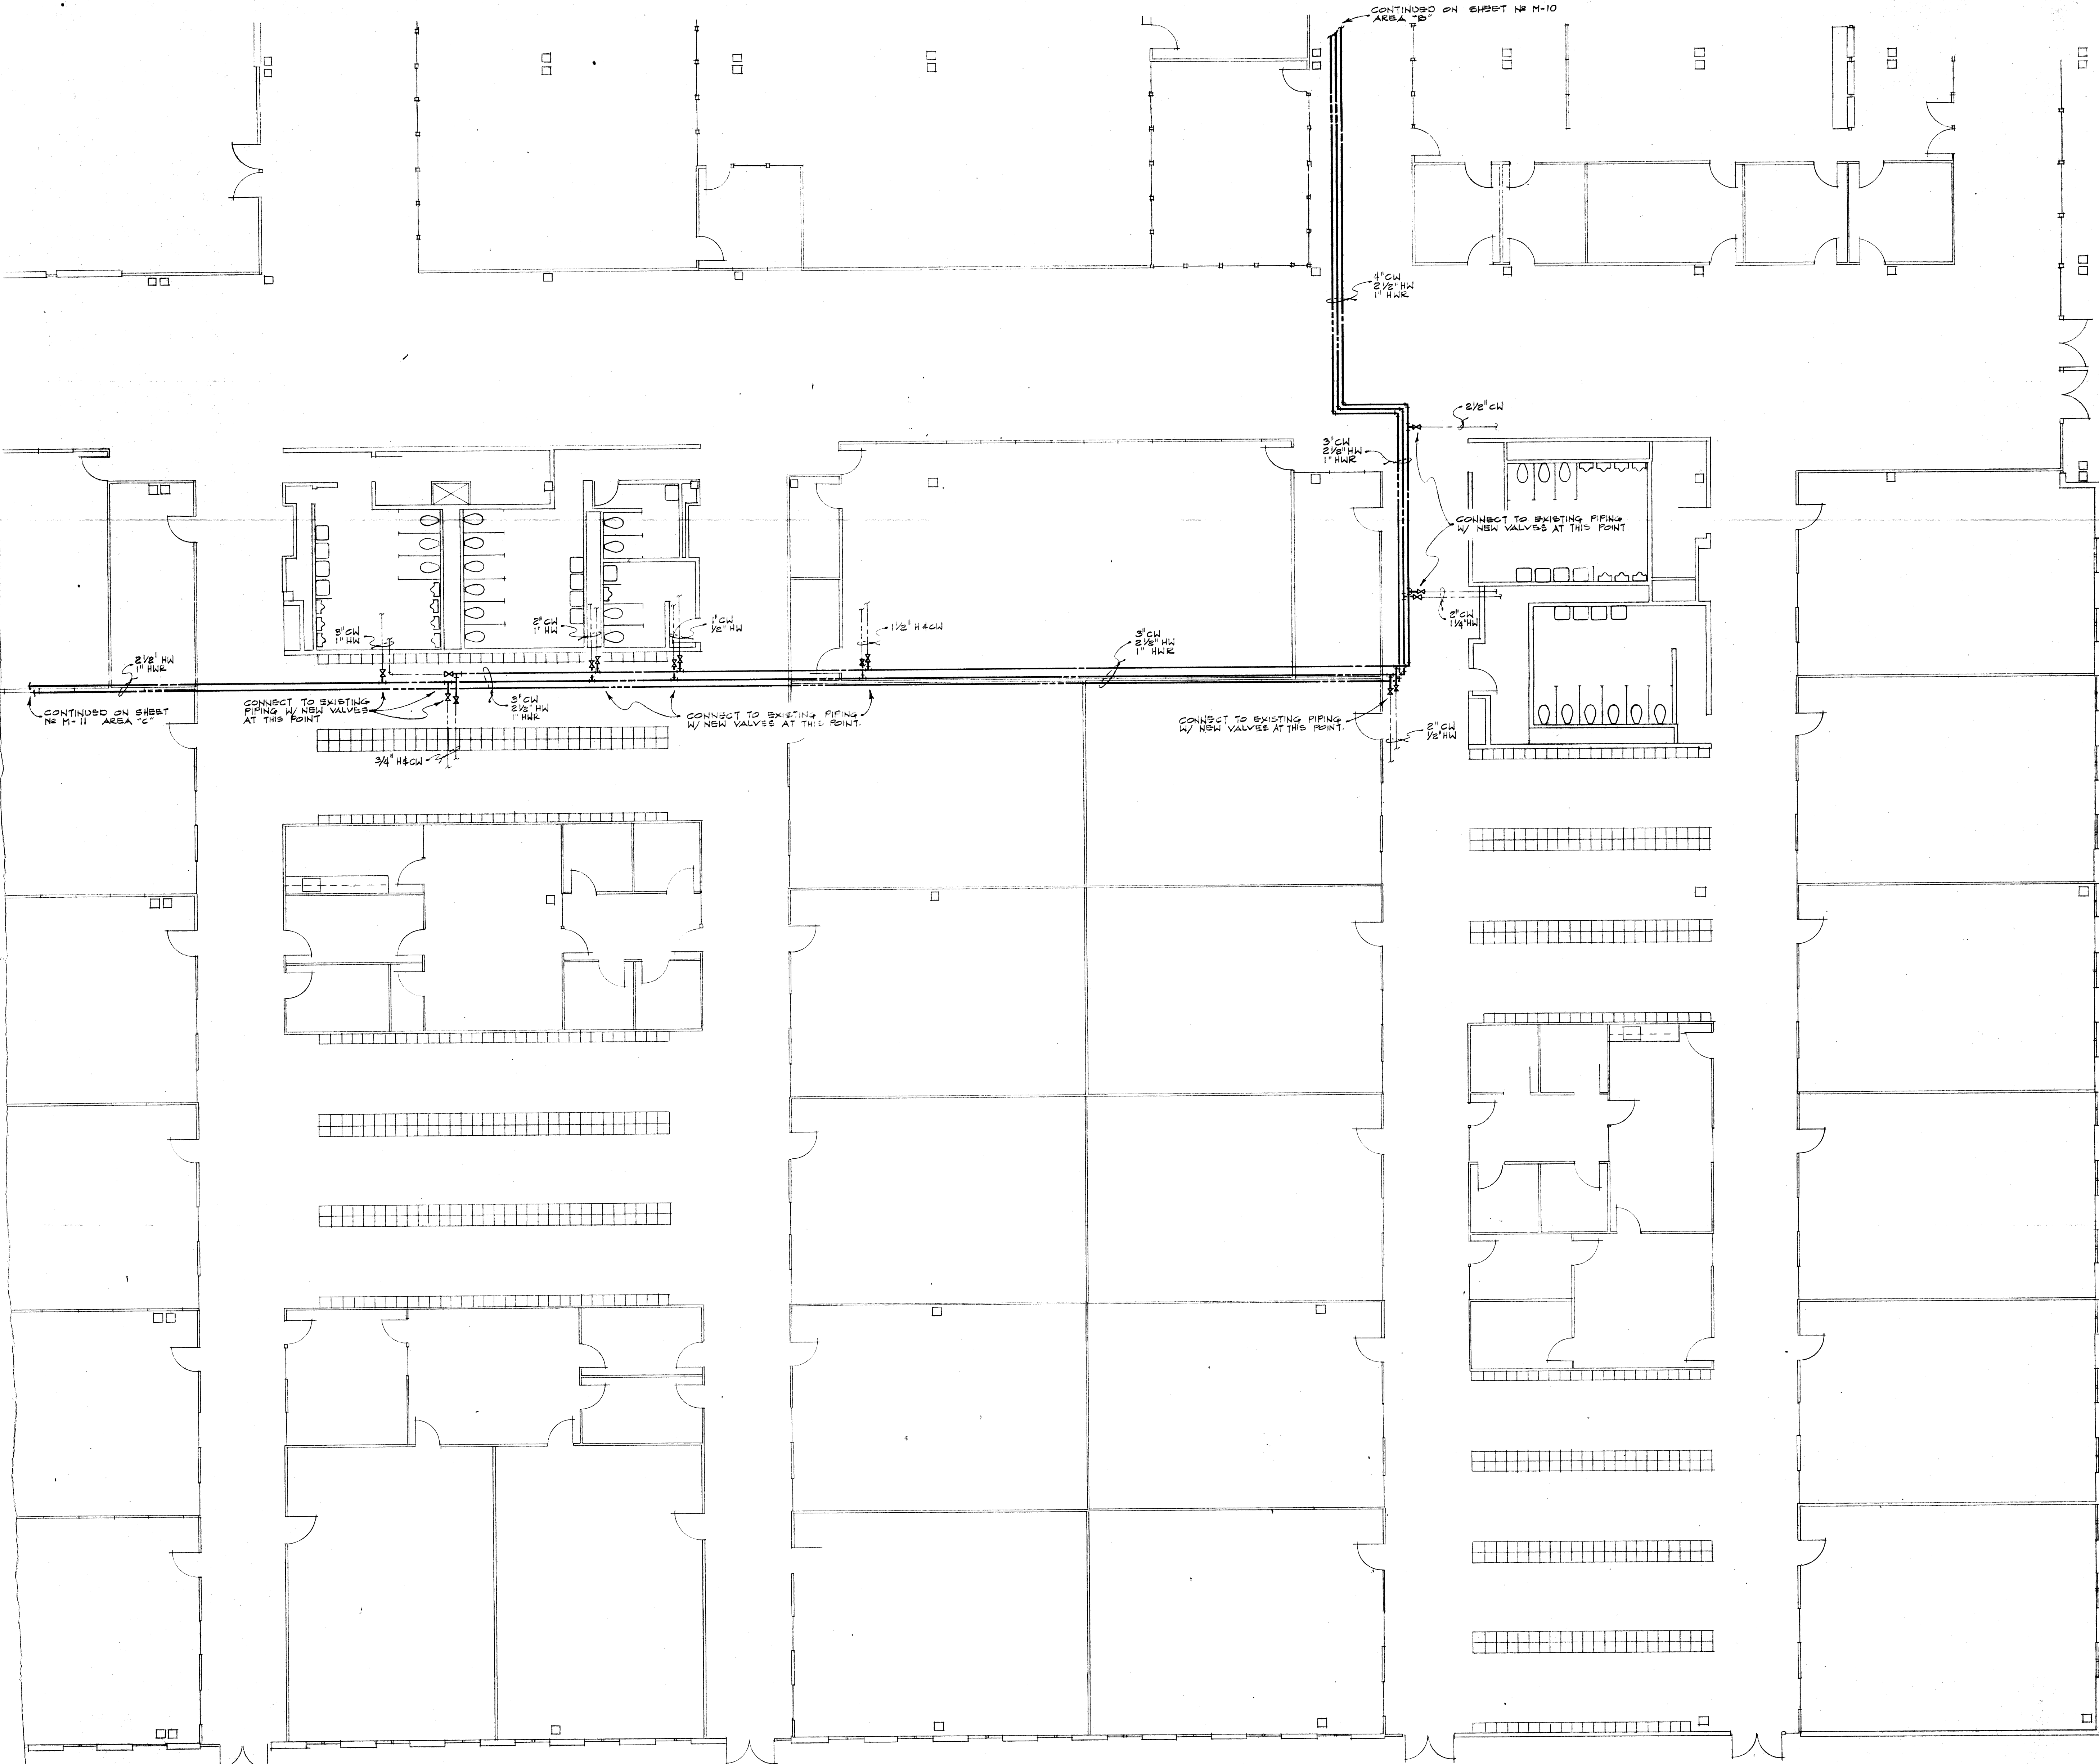


AREA "A"- MECHANICAL FLOOR PLAN
SCALE: 1/8"=1'-0"

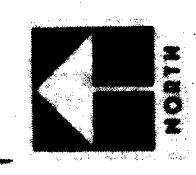

PLAN NOTES

1. All heavy drawn piping on this sheet is new and replaces existing in same location. This Contractor shall remove existing piping and replace with new including connections to branch lines as shown. Insulate all new pipe as spec filed.
2. This Contractor shall be responsible for the removal and replacement of the existing ceiling tiles in like or better condition than existing.
3. This Contractor shall be advised that no work on this sheet shall begin before May 28, 1982.
4. The layout of the existing piping shown is illustrative only. No attempt has been made to show the piping exactly as it exists. The Contractor shall be responsible for determining the exact layout and size of the piping and equipment before he submits his bid and shall take the same in account in pricing his bid. He shall accept the piping and equipment as he finds it and shall provide all the material, equipment and labor necessary to complete the work in the manner intended.
5. All new piping shown shall be insulated as indicated in the specifications unless otherwise noted.
6. Any of existing ferrous or non-ferrous piping, hangers, etc. removed from the areas of work by the contractor shall be turned over to the Owner.
7. All existing debris and debris created by this contract in the work areas shall be immediately removed from the job site.

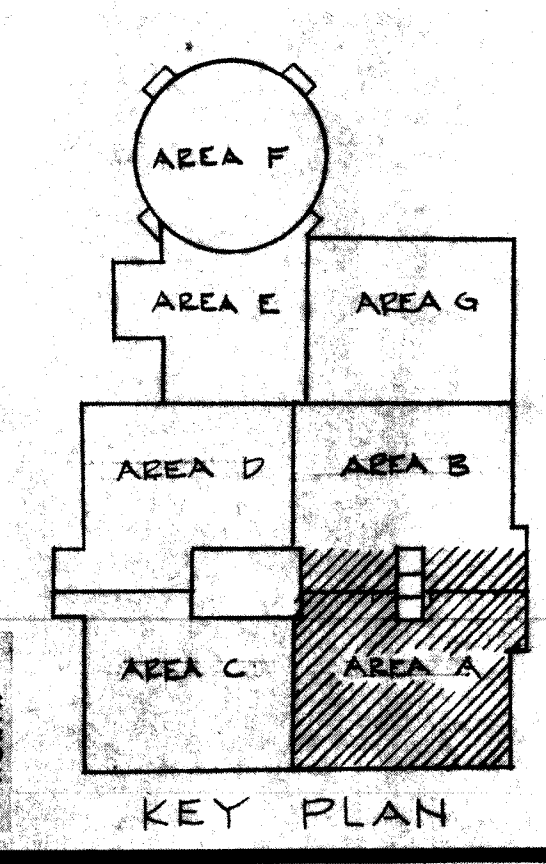

WRIGHT PORTER & LOWE INC.
ARCHITECTS - ENGINEERS
INDIANAPOLIS, INDIANA

COGILL/OBERLIES & ASSOCIATES
Consulting Engineers
INDIANAPOLIS, INDIANA


UNIT A - FLOOR PLAN

METROPOLITAN SCHOOL DISTRICT
OF LAWRENCE TOWNSHIP
LAWRENCE CENTRAL HIGH SCHOOL

NO.	DATE	REVISIONS	DESCRIPTION	CONTR. NO.	DATE
1	5/20/82				
2	7/20/82				
3					
4					
5					
6					
7					
8					
9					
10					

CERTIFIED BY: [Signature]
DATE: 5/20/82


M-9
OF 13

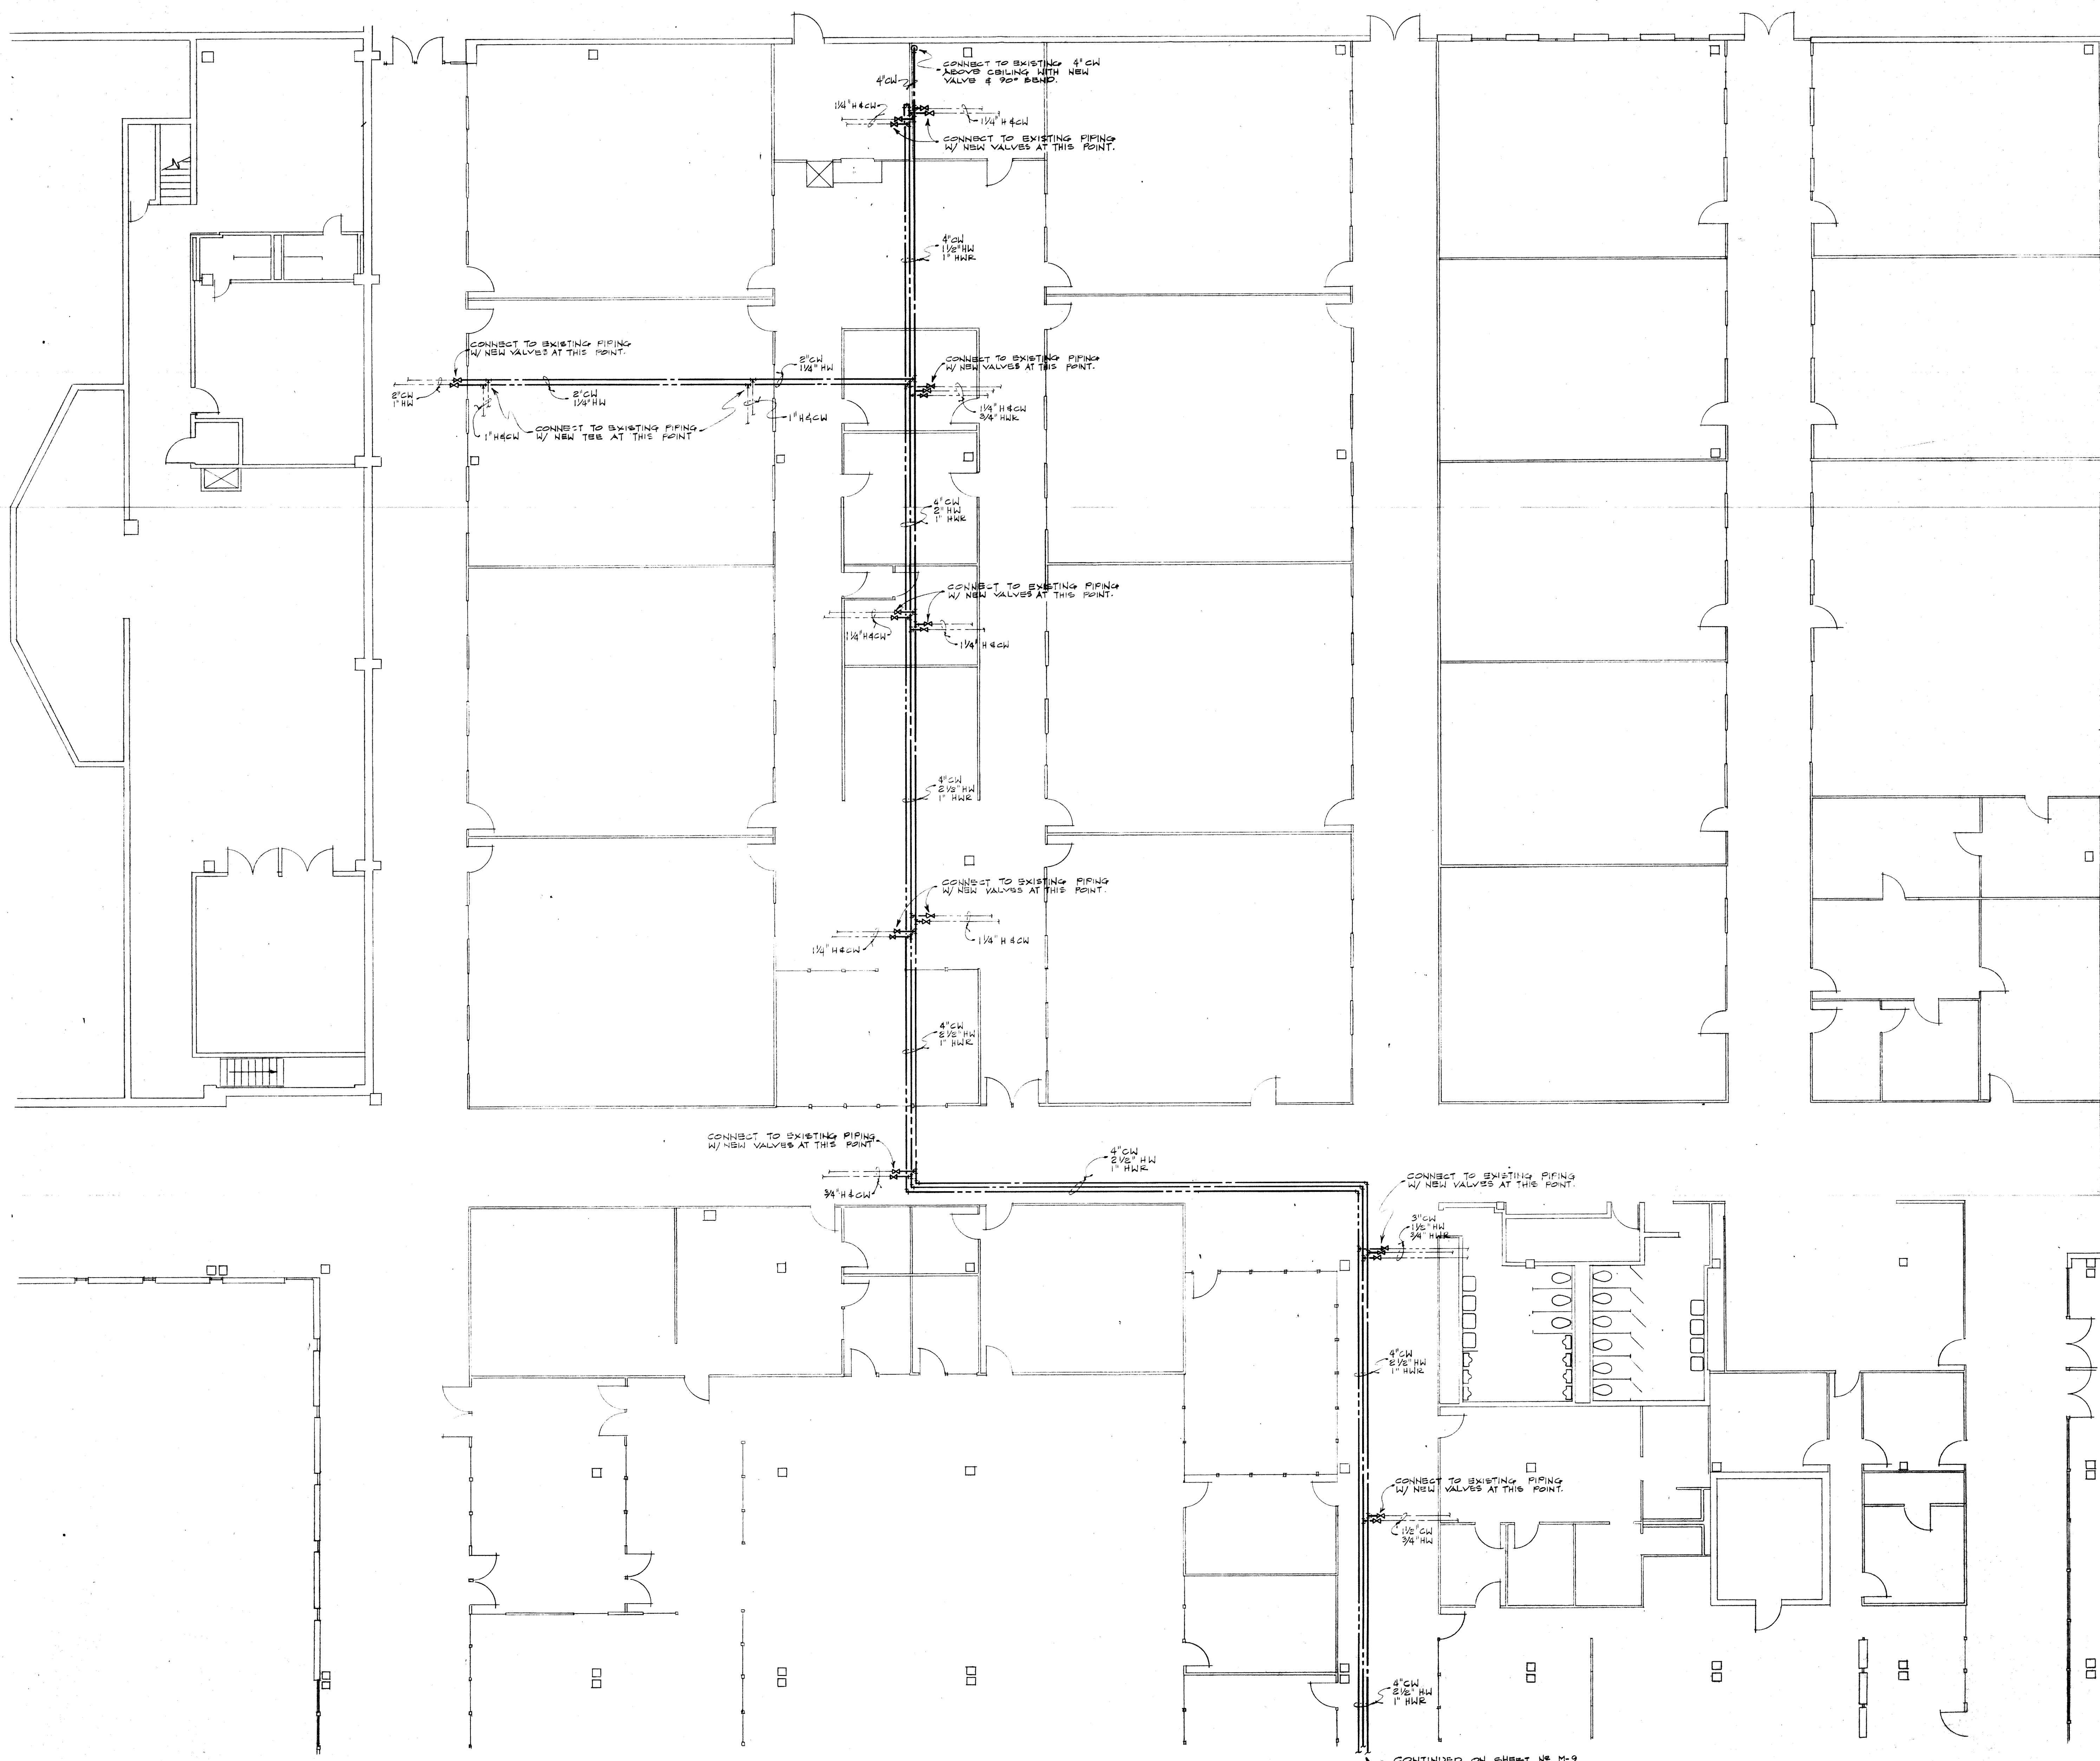

AREA "B" - MECHANICAL FLOOR PLAN
SCALE: 1/8" = 1'-0"

PLAN NOTES

1. All heavily drawn piping on this sheet is new and replaces existing in same location. This Contractor shall remove existing piping and replace with new including connections to branch lines as shown. Insulate all new pipe as specified.
2. This Contractor shall be responsible for the removal and replacement of the existing ceiling tiles in like or better condition than existing.
3. This Contractor shall be advised that no work on this sheet shall begin before May 28, 1982.
4. The layout of the existing piping shown is illustrative only. No attempt has been made to show the piping exactly as it exists. The Contractor shall be responsible for determining the exact layout and size of the piping and equipment before he submits his bid and shall take the same in account in pricing his bid. He shall accept the piping and equipment as he finds it and shall provide all the material, equipment and labor necessary to complete the work in the manner intended.
5. All new piping shown shall be insulated as indicated in the specifications unless otherwise noted.
6. Any of existing ferrous or non-ferrous piping, hangers, etc. removed from the areas of work by the contractor shall be turned over to the Owner.
7. All existing debris and debris created by this contract in the work areas shall be immediately removed from the job site.

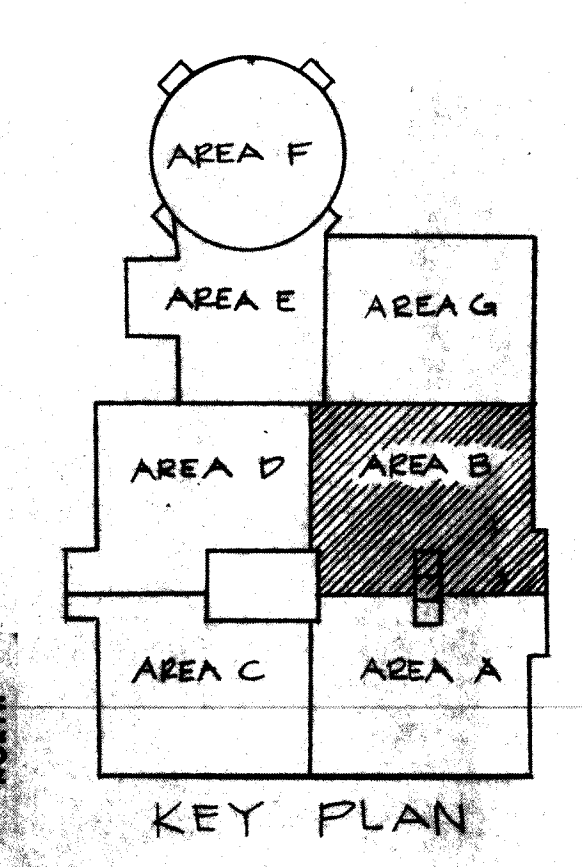

WRIGHT PORTER & LOWE INC.
ARCHITECTS, ENGINEERS
INDIANAPOLIS, INDIANA

COGHILL/OBERLIES & ASSOCIATES
Consulting Engineers
INDIANAPOLIS, INDIANA


UNIT B - FLOOR PLAN

**METROPOLITAN SCHOOL DISTRICT
OF LAWRENCE TOWNSHIP**
LAWRENCE CENTRAL HIGH SCHOOL

NO.	DATE	REVISIONS	DESCRIPTION	CONV. NO.	DATE
1	8/20/81				
2	11-30-81				
3					
4					
5					
6					
7					
8					
9					
10					


CERTIFIED BY: [Signature]
DATE: 8/20/81

M-10
of 13

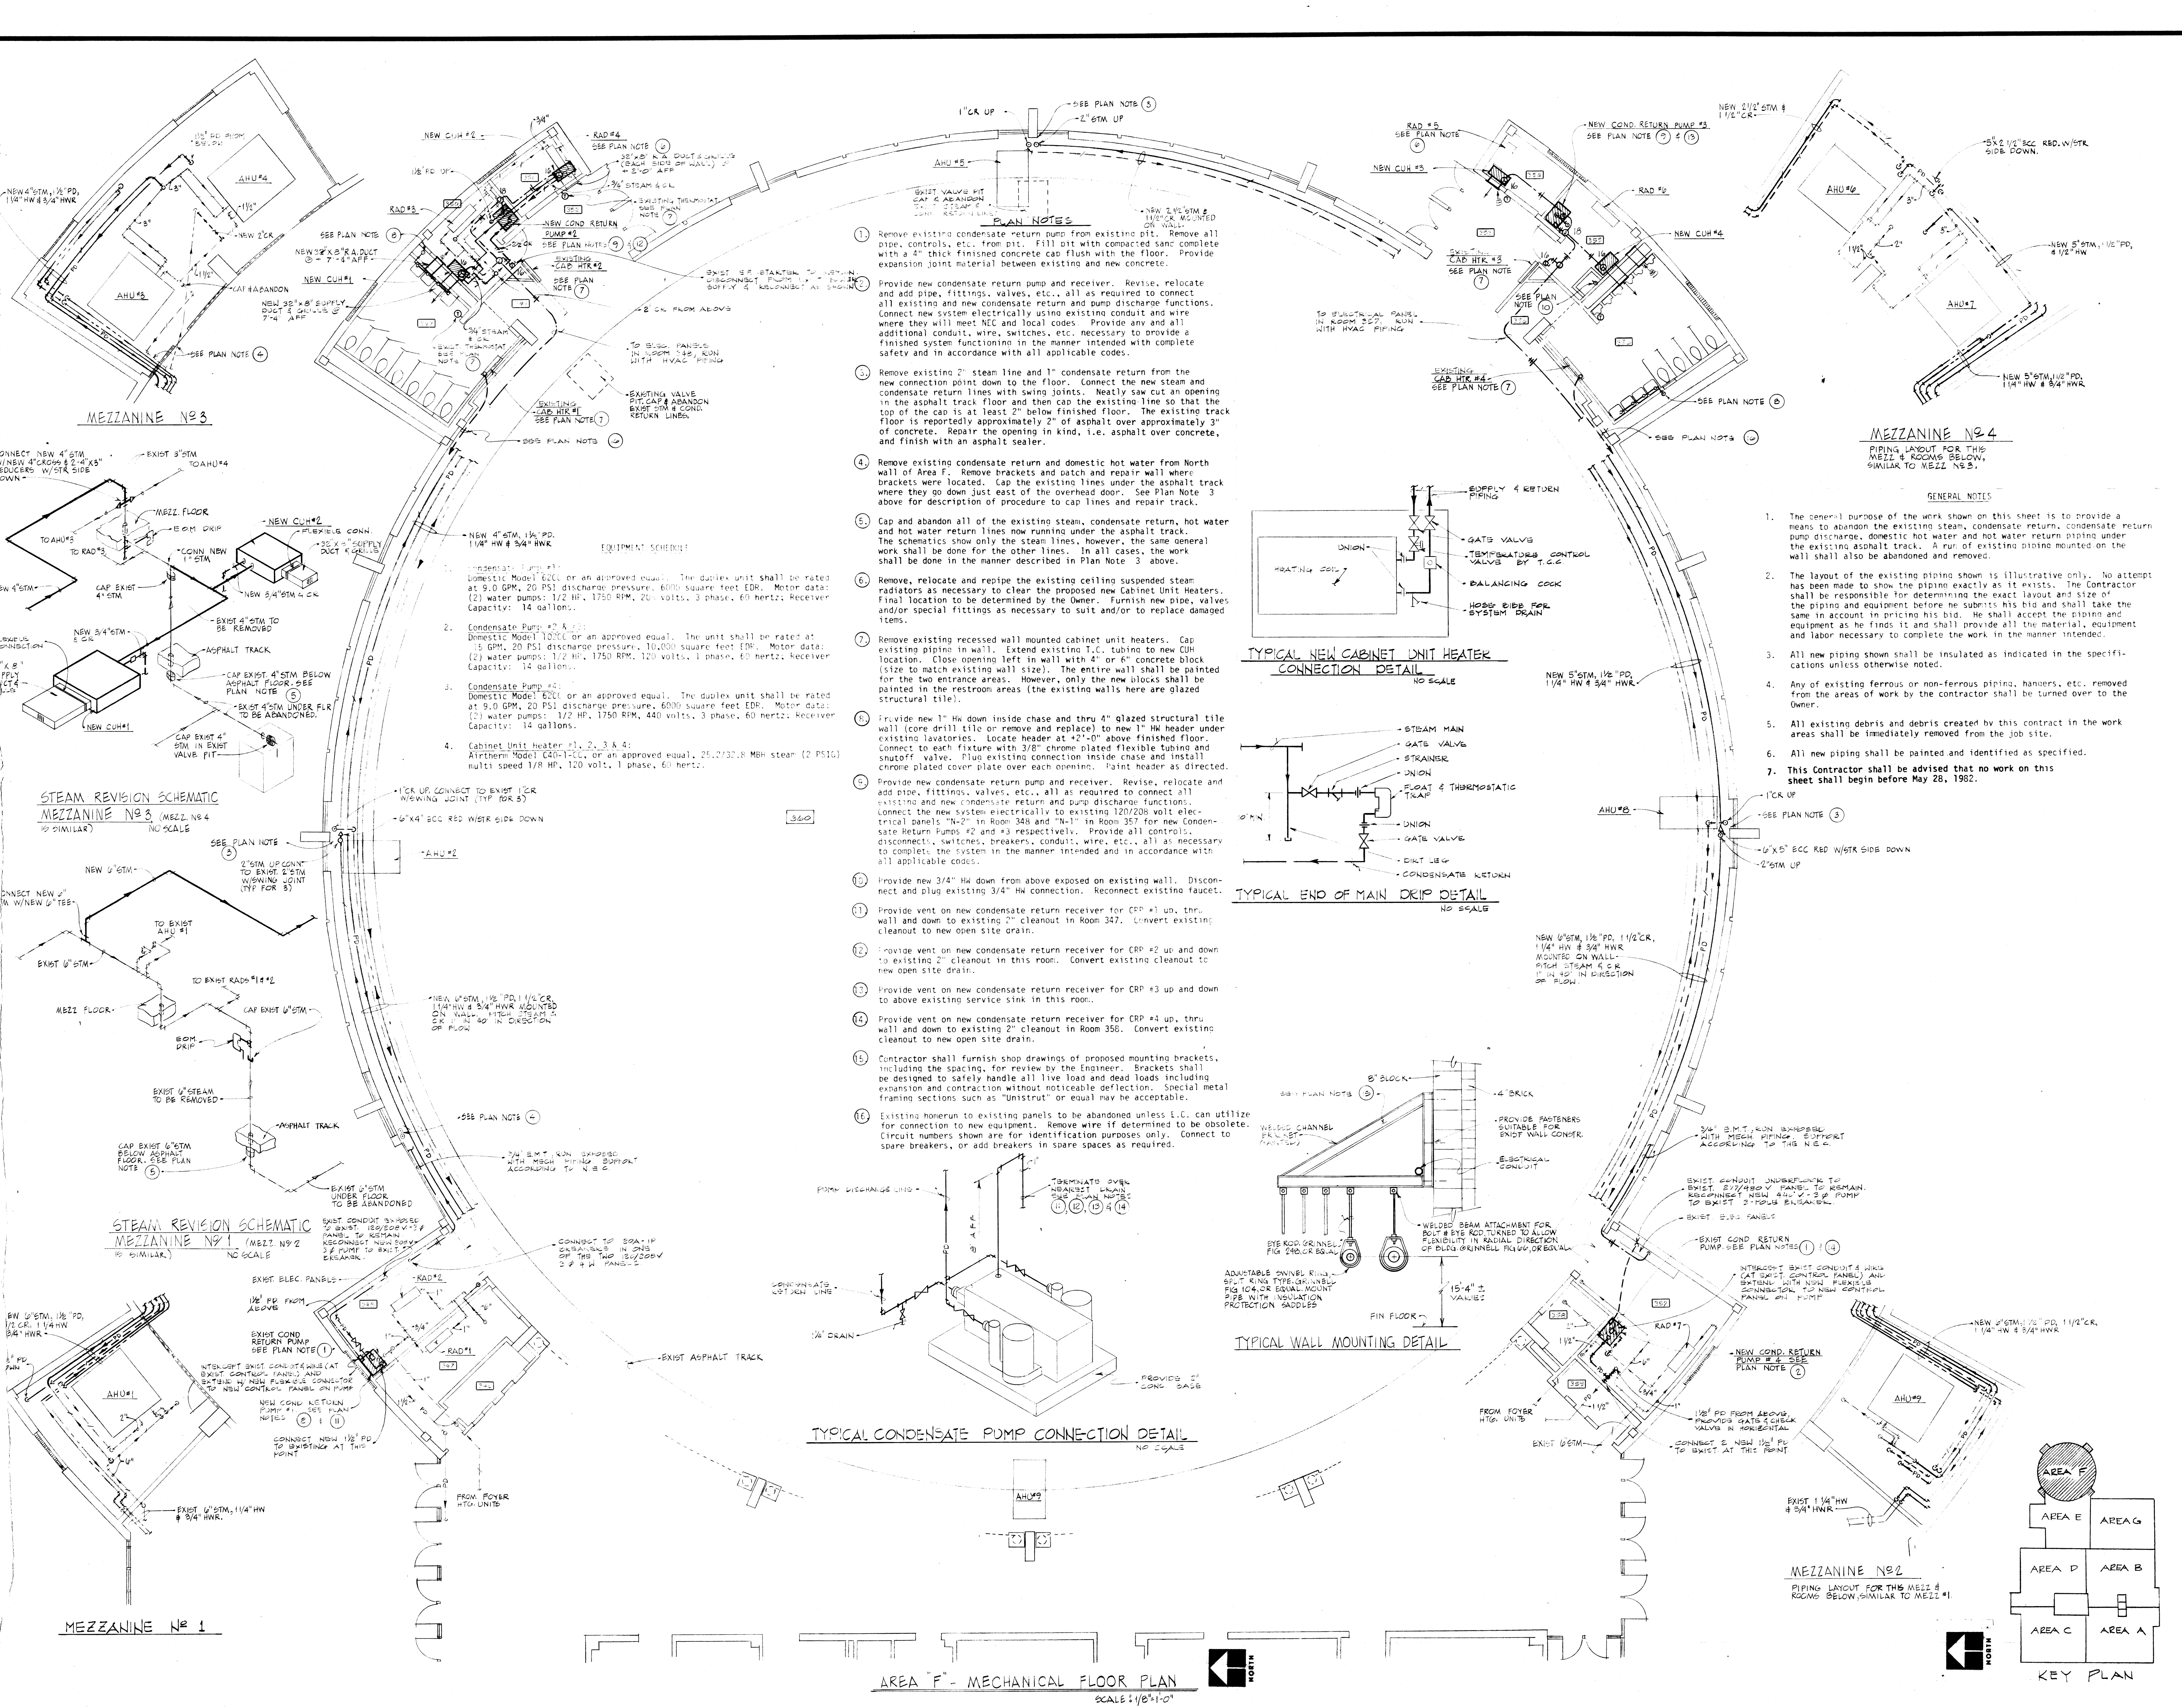

AREA "F" - MECHANICAL FLOOR PLAN

SCALE: 1/8"=1'-0"

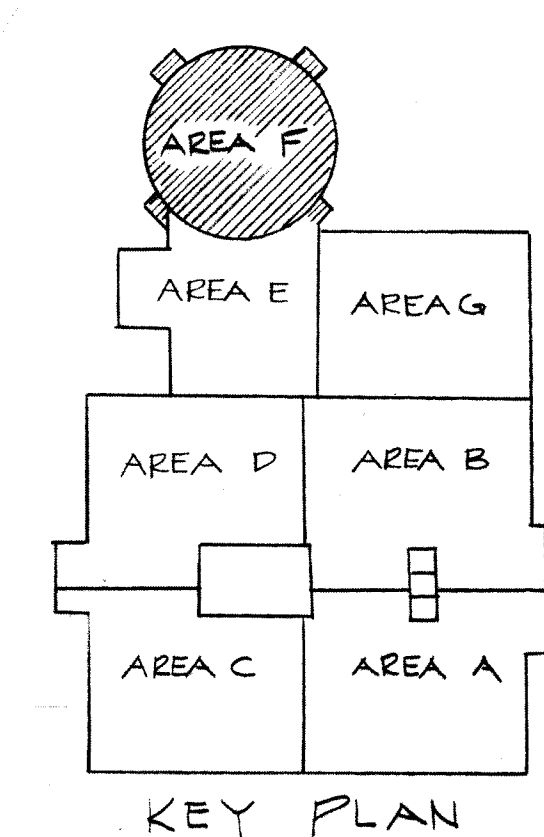

KEY PLAN

WRIGHT PORTER & LOWE INC.
ARCHITECTS - ENGINEERS
INDIANAPOLIS, INDIANA

COGILL/OBERLIES & ASSOCIATES
Consulting Engineers
INDIANAPOLIS, INDIANA

UNIT F - FLOOR PLAN

METROPOLITAN SCHOOL DISTRICT
OF LAWRENCE TOWNSHIP
LAWRENCE CENTRAL HIGH SCHOOL

NO.	DATE	REVISIONS
1	11-20-81	DATE
2	11-20-81	DATE
3	11-20-81	DATE
100	11-20-81	DATE

ENGINEER
No. 13866
State of INDIANA
Professional Engineer

CERTIFIED BY

NO. 12

of 13

