

ADDENDUM NO. 1

April 9, 2025

AMES FIELD EXTERIOR IMPROVEMENTS Michigan City, IN 46360

TO: ALL BIDDERS OF RECORD

This Addendum forms a part of and modifies the Bidding Requirements, Contract Forms, Contract Conditions, the Specifications, and the Drawings dated March 27, 2025 by Fanning Howey Associates, Inc. Acknowledge receipt of the Addendum in the space provided on the Bid Form. Failure to do so may subject the Bidder to disqualification.

This Addendum consists of Pages ADD 1-1.

A. SPECIFICATION SECTION 00 20 00 – INFORMATION AVAILABLE TO BIDDERS

1. **Add:**
 - a. 1994 Ames Field Construction Documents
 - b. 1994 Ames Field Precast Concrete Drawings

MICHIGAN CITY AREA SCHOOLS MICHIGAN CITY SPORTS COMPLEX AMES FIELD

MICHIGAN CITY, INDIANA

MAY 31, 1994

SCHOOL BOARD

ROBERT R. JACKSON	PRESIDENT
J. JEFFREY JONES	VICE PRESIDENT
DENNIS MARTIN	SECRETARY
BERNARD H. BROWN	MEMBER
MARYKAYE GRAMS-NEITZEL	MEMBER
GREGG P. HANKE	MEMBER
MELVIN MERIWEATHER, JR.	MEMBER

SCHOOL ADMINISTRATION

DR. NATHANIEL CLAY	SUPERINTENDENT
MR. ROBERT HARBART	ASSOCIATE SUPERINTENDENT
MR. RICHARD G. COOK	ASSISTANT SUPERINTENDENT
MRS. ARDYS MORGAN	ASSISTANT SUPERINTENDENT
MR. JEFFRY C. KUTCH, P.E.	ADMINISTRATIVE ASSISTANT-PLANT PLANNING

THE ODLE McGUIRE & SHOOK CORPORATION

ARCHITECTURE ■ ENGINEERING ■ LANDSCAPE ARCHITECTURE ■ INTERIOR DESIGN

6765 NORTH STATE ROAD 37, POST OFFICE BOX 2149, BLOOMINGTON, INDIANA 47402, 812/876-2020
8275 ALLISON POINTE TRAIL, POST OFFICE BOX 50428, INDIANAPOLIS, INDIANA 46250, 317/842-0000

LIST OF ABBREVIATIONS

L	ANGLE	MAX	MAXIMUM
A/V	AUDIO VISUAL	MB	MECHANICAL
ACP	ACOUSTICAL CEILING PANEL	MECH	MECHANICAL
ADD	ADDENDUM	MFR	MANUFACTURER
ADJ	ADJUSTABLE	MIN	MINIMUM/MINUTE
AFF	ABOVE FINISH FLOOR	MISC	MISCELLANEOUS
AHU	AIR HANDLING UNIT	MO	MASONRY OPENING
ALT	ALTERNATE	MTG	MOUNTING
ALUM	ALUMINUM	MTL	METAL
APPROX	APPROXIMATE	MULL	MULLION
ARCH	ARCHITECT/ARCHITECTURAL	N/A	NOT APPLICABLE
AWP	ACOUSTICAL WALL PANEL	N/S	NON-SLIP
BD	BOARD	NC	NOT IN CONTRACT
BLDG	BUILDING	NO	NUMBER
BLKG	BLOCKING	NOM	NOMINAL
BM	BEAM	NTS	NOT TO SCALE
BOS	BOTTOM OF STRUCTURE	OD	OUTSIDE DIAMETER
BOT	BOTTOM	OP	OPERABLE PANEL
BRG	BEARING	OPP	OPPOSITE
BRK	BRICK	PL	PLATE
BRNZ	BRONZE	P	PAINT
BSMT	BASEMENT	PART. BD	PARTICLE BOARD
C	CENTERLINE	PC	PRECAST CONCRETE
C3	CHALKBOARD	PLAS	PLASTER
CF	COMPUTER FLOOR	PLAS. LAM	PLASTIC LAMINATE
CJ	CONTROL JOINT	PLBG	PLUMBING
CLG	CEILING	PLYWD	PLYWOOD
CLR	CLEAR	PR	PAIR
CMU	CONCRETE MASONRY UNIT	PSF	POUNDS PER SQUARE FOOT
COL	COLUMN	PSI	POUNDS PER SQUARE INCH
CONC	CONCRETE	PVC	POLYVINYL CHLORIDE
CONF	CONFERENCE	QT	QUARRY TILE
CONST	CONSTRUCTION	QTY	QUANTITY
CONT	CONTINUOUS	R	RADIUS/RISER
CORR	CORRIDOR	RB	RESILIENT BASE
CP	CEMENT PLASTER	RCP	REINFORCED CONCRETE PIPE
CPT	CARPET	RD	ROOF DRAIN
CT	CERAMIC TILE	REFR	REFRIGERATOR
CU FT	CUBIC FEET	REINF	REINFORCED/REINFORCING
CU YD	CUBIC YARD	RES	RESILIENT
D	DEPTH/DEEP	REV	REVISION
DBL	DOUBLE	RO	ROUGH OPENING
DEPT	DEPARTMENT	ROD	ROOF OVERFLOW DRAIN
DISP	DISPENSER/DISPOSAL UNIT	RT	RUBBER TILE
DN	DOWN	S/S	STAINLESS STEEL
DS	DOWNSPOUT	SAN	SANITARY
DTL	DETAIL	SC	SPECIAL COATING
DW	DISHWASHER	SCHED	SCHEDULED
DWG	DRAWING	SECT	SECTION
EA	EACH	SF	SQUARE FEET/STAGE FLOORING
ELEC/ELECT	ELECTRIC/ELECTRICAL	SGF	SYNTHETIC GYM FLOORING
ELEV/EL	ELEVATION/ELEVATOR	SHT	SHEET
EMER	EMERGENCY	SHTG	SHEATHING
ENCL	ENCLOSURE	SM	SIMILAR
ENT	ENTRANCE	SLNT	SEALANT
EQ	EQUAL	SLR	SEALER
EQUIP	EQUIPMENT	SPEC(S)	SPECIFICATION(S)
ES	EXPOSED STRUCTURE	SQ FT	SQUARE FOOT/FEET
ESP	EXPOSED STRUCTURE PAINTED	SO	SQUARE
EWG	ELECTRIC WATER COOLER	STD	STANDARD
EXP	EXPANSION	STL	STEEL
EXP. JT/EJ	EXPANSION JOINT	STOR	STORAGE
EXT	EXTERIOR	STRUCT	STRUCTURAL
FD	FLOOR DRAIN	SUSP	SUSPENDED
FE	FIRE EXTINGUISHER	T&G	TONGUE AND GROOVE
FEC	FIRE EXTINGUISHER CABINET	TB	TACKBOARD
FFEL	FINISHED FLOOR ELEVATION	TEL	TELEPHONE
FLR	FLOOR/FLOORING	TEMP	TEMPERED
FRG	FURRING	THK	THICK
FRP	FIBERGLASS REINFORCED PLASTIC	TOS	TOP OF SLAB
FRPF	FIREPROOF	TOW	TOP OF WALL
FT	FEET/FOOT	TRNSPT	TRANSPARENT
FTG	FOOTING	TRD	TREAD
GA	GAUGE	TYP	TYPICAL
GALV	GALVANIZED	TZ	TERRAZZO
GSF	GROSS SQUARE FEET	UNO	UNLESS NOTED OTHERWISE
GWB	GYPSUM WALL BOARD	UL	UNDERWRITERS' LABORATORY
HC	HANDICAPPED	VAR	VARIABLES
HDWR	HARDWARE	VCT	VINYL COMPOSITION TILE
HM	HOLLOW METAL	VENT	VENTILATOR/VENTILATION
HORIZ	HORIZONTAL	VERT	VERTICAL
HT	HEIGHT	VEST	VESTIBULE
HTG	HEATING	VIF	VERIFY IN FIELD
HVAC	HEATING, VENTILATING, AIR CONDITIONING	VR	VAPOR RETARDER
IBC	INDIANA BUILDING CODE	VTR	VENT THROUGH ROOF
ID	INSIDE DIAMETER	VWC	VINYL WALL COVERING
IN	INCH	W/M/WF	WELDED WIRE MESH/FABRIC
INSUL	INSULATION	W/O	WITHOUT
INT	INTERIOR	W	WIDTH/WIDE
JAN	JANITOR	W/	WITH
JT	JOINT	WC	WATER CLOSET
KIT	KITCHEN	WO	WOOD
L	LENGTH	WDG	WOOD DIRECT GLUED
LAV	LAVATORY	WP	WALL PADDING
LS	LIMESTONE	WSCOT	WAINSCOT
		WT	WEIGHT

SYMBOL LEGEND

	SECTION		ROOM NAME & NUMBER
	DETAIL		EQUIPMENT TYPE
	ELEVATION		BORROWED LIGHT NUMBER
	FINISHED FLOOR ELEVATION		PLAN NOTES
	GRID LINE		DOOR NUMBER
			WINDOW TYPE NUMBER

CODE SUMMARY

- OCCUPANCY CLASSIFICATION**
THE OCCUPANCY CLASSIFICATION IS A-4. THE LOCKER ROOMS, REST ROOMS, AND STORAGE AREAS ARE TO SUPPORT THIS OCCUPANCY. THE LAWN EQUIPMENT STORAGE AREA WILL NOT HAVE FLAMMABLE LIQUIDS THAT EXCEED THE LIMITS OF TABLE 9A OF THE INDIANA BUILDING CODE.
- CONSTRUCTION TYPE**
THE REQUIRED CONSTRUCTION TYPE OF THE STRUCTURE IS II - ONE HOUR. THE ACTUAL MATERIALS WILL BE CONCRETE BLOCK AND POURED CONCRETE.
- STORIES ABOVE GRADE**
THE HEIGHT OF THE LAST SEAT OF THE STANDS DOES NOT EXCEED THE 55 FOOT LIMIT PER TABLE 5-D OF THE INDIANA BUILDING CODE FOR AN A-4, II - ONE HOUR BUILDING.
- ALLOWABLE AREA**
THE AREA OF THE BUILDING IS 12,300 SQUARE FEET. THE BASIC ALLOWABLE AREA OF THE BUILDING IS:
10,500 SQUARE FEET PER TABLE 5-C
X 100% YARD INCREASE PER SECTION 506 I.B.C.
21,000 ALLOWABLE
- FIRE SUPPRESSION**
THE BLEACHERS ARE SEPARATED FROM THE AREA BENEATH BY A ONE HOUR OCCUPANCY SEPARATION THAT IS REQUIRED BY SECTION 602 (e)2 OF THE I.B.C.
- NUMBER OF OCCUPANTS**
THE SEATING CAPACITY OF THE STANDS IS 3032 SEATS.
- EXITING REQUIREMENTS**
A. NUMBER AND WIDTH OF EXITS ARE PROVIDED IN ACCORDANCE WITH SECTION 3322 (g)7 I.B.C. THE OPEN AIR STANDS REQUIRE A MINIMUM OF FOUR EXITS. EXIT WIDTH IS DIVIDED BETWEEN STAIRS AND RAMPS. THE STAIRS ARE EACH 8 FEET WIDE AND THE RAMPS ARE 7 FEET WIDE. THE EXIT POTENTIAL CAN BE CALCULATED BY THE OCCUPANT FACTORS OF SECTION 3322 (g)8 I.B.C.:
STAIRS:
2 STAIRS x 8 FEET = 16 FEET OF EXIT WIDTH.
16 FEET x THE OCCUPANT FACTOR OF 150 PEOPLE PER FOOT = 2,400 PEOPLE.
RAMPS:
2 RAMPS x 7 FEET = 14 FEET OF EXIT WIDTH.
14 FEET x THE OCCUPANT FACTOR OF 200 PEOPLE PER FOOT = 2,800 PEOPLE.
TOTAL:
THE EXIT WIDTH COULD HANDLE A TOTAL OF 5,200 PEOPLE. THE STANDS ONLY SEAT 3032 PEOPLE.
B. THE TEAM LOCKER ROOMS REQUIRE TWO EXITS PER TABLE 33-A I.B.C.. THE EXITS ARE MORE THAN 50% OF THE TRAVEL DISTANCE APART. ONE EXITS INTO THE LOCKER LOBBY AND ONE INTO THE STAIRCASE.
- GUARDRAILS**
THE GUARDRAILS WILL NOT ALLOW FOR A SPHERE OF FOUR INCHES IN DIAMETER TO PASS THROUGH THEM.
- FIRE RESISTIVE REQUIREMENTS**
THE ELECTRICAL ROOM IS SEPARATED FROM THE STORAGE ROOM PER THE INDIANA ELECTRICAL CODE AND IS CONSTRUCTED OF ONE HOUR WALLS. THE MECHANICAL AREA IS ISOLATED TO INSURE THE PROPER CLEARANCES PER THE INDIANA MECHANICAL CODE.
- PLUMBING REQUIREMENTS**
THE PLUMBING FIXTURE COUNT EXCEEDS THE REQUIREMENTS OF TABLE 5-E I.B.C.
3032 PEOPLE / 2 = 1516 MEN 1516 WOMEN
11 REQUIRED FIXTURES 16 REQUIRED FIXTURES
13 PROVIDED 17 PROVIDED
- ACCESSIBILITY**
THE BUILDING IS FULLY HANDICAPPED ACCESSIBLE INCLUDING:
A. SEATING LOCATIONS
B. RESTROOMS
C. ELEVATOR TO PRESSBOX
D. RAMPS
E. SHOWERS
F. PROTECTED PIPES UNDER THE SINKS

MATERIALS LEGEND

	CMU		METAL STUD & G.W.B. (PLAN)		STEEL (SECTION)
	BRICK		MARBLE/TERRAZZO		LIMESTONE
	CONCRETE		GYPSUM WALL BOARD		RIGID INSULATION
	COMPACTED SAND		WOOD (ROUGH)		BATT INSULATION
	ASPHALT PAVING		NOT USED		ACOUSTICAL PANEL/TILE
	EARTH (FILL OR UNDISTURBED)		PLYWOOD		COMPACTED GRANULAR FILL

LIST OF DRAWINGS

COVER SHEET
INDEX

SITE/CIVIL

L100	SITE SURVEY
L101	DEMOLITION PLAN
L102	LAYOUT PLAN
L103	GRADING AND DRAINAGE PLAN
L104	SITE DETAILS
L105	SITE DETAILS AND ENLARGEMENT PLANS
L106	PLANTING PLAN

ARCHITECTURAL

A201	FLOOR PLAN-FOOTBALL GRANDSTAND
A202	FLOOR PLANS-VISITOR CONCESSION/TOILET TICKET BOOTH
A203	REFLECTED CEILING PLANS
A204	ENLARGED TOILET PLANS
A205	ROOF PLANS & ROOF DETAILS
A301	ELEVATIONS-FOOTBALL GRANDSTAND
A302	ELEVATIONS-FOOTBALL GRANDSTAND, VISITOR CONCESSION/TOILET, TICKET BOOTH, SITE WALL/FENCE BUILDING SECTIONS
A401	WALL SECTIONS
A402	WALL SECTIONS
A403	WALL SECTIONS & MISC.
A501	ROOM FINISH SCHEDULE & DOOR SCHEDULE
A502	DOOR DETAILS
A601	PLAN DETAILS
A602	PLAN DETAILS
A603	MISCELLANEOUS DETAILS
A604	SIGNAGE

STRUCTURAL

S201	FOUNDATION PLAN
S202	FOUNDATION PLAN AND FRAMING PLAN
S203	ROOF FRAMING PLAN
S401	SECTIONS AND DETAILS

MECHANICAL

MP101	MECHANICAL & PLUMBING SYMBOLS & ABBR.
M201	HVAC FLOOR PLANS FOOTBALL GRANDSTAND
M202	HVAC FLOOR PLANS-VISITOR TOILET/CONCESSION, TICKET BOOTH
M301	HVAC SCHEDULES
M302	HVAC DETAILS


PLUMBING

P101	PLUMBING SITE PLAN
P201	PLUMBING FOUNDATION FOOTBALL GRANDSTAND PLAN
P202	PLUMBING FOUNDATION VISITOR TOILET & CONCESSION, GRANDSTAND PRESSBOX
P203	PLUMBING FOOTBALL GRANDSTAND FLOOR PLAN
P204	PLUMBING VISITOR TOILET & CONCESSION, GRANDSTAND PRESSBOX
P501	PLUMBING SCHEDULES & DETAILS
P502	PLUMBING DETAILS & ISOMETRICS

ELECTRICAL


E101	ELECTRICAL SITE PLAN
E201	FOOTBALL GRANDSTAND LIGHTING PLAN
E202	FOOTBALL GRANDSTAND POWER AND SIGNAL
E203	FOOTBALL GRANDSTAND, VISITOR CONCESSION/TOILET AND TICKET BOOTH LIGHTING PLAN
E204	FOOTBALL GRANDSTAND, VISITOR CONCESSION/TOILET AND TICKET BOOTH POWER AND SIGNAL
E301	ELECTRICAL SYMBOL, LEGEND
E302	ELECTRICAL RISER DIAGRAM
E303	LIGHT FIXTURE SCHEDULE
E304	PANEL SCHEDULE

VICINITY MAP

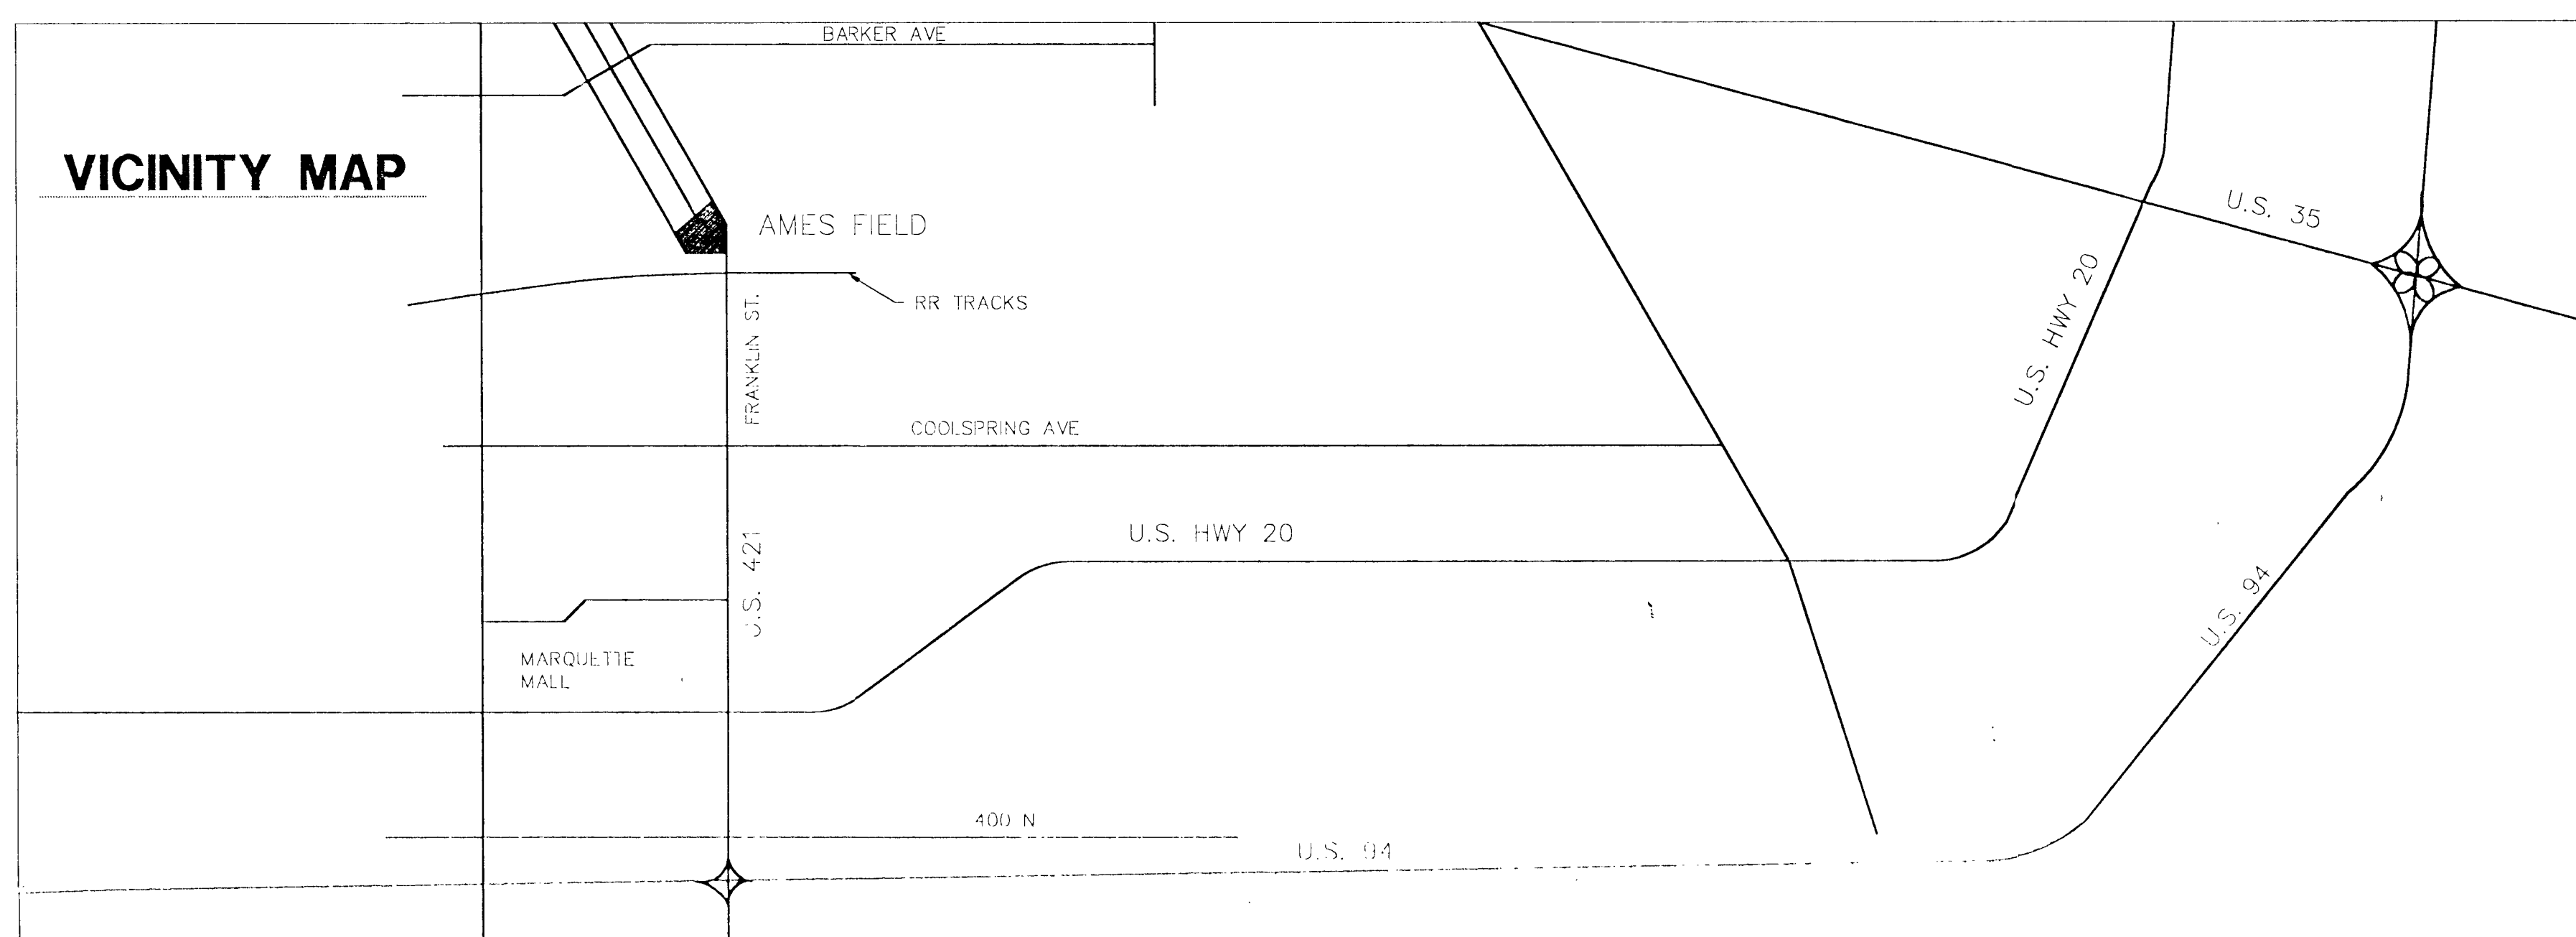

JOB SIGN

SCALE: NONE

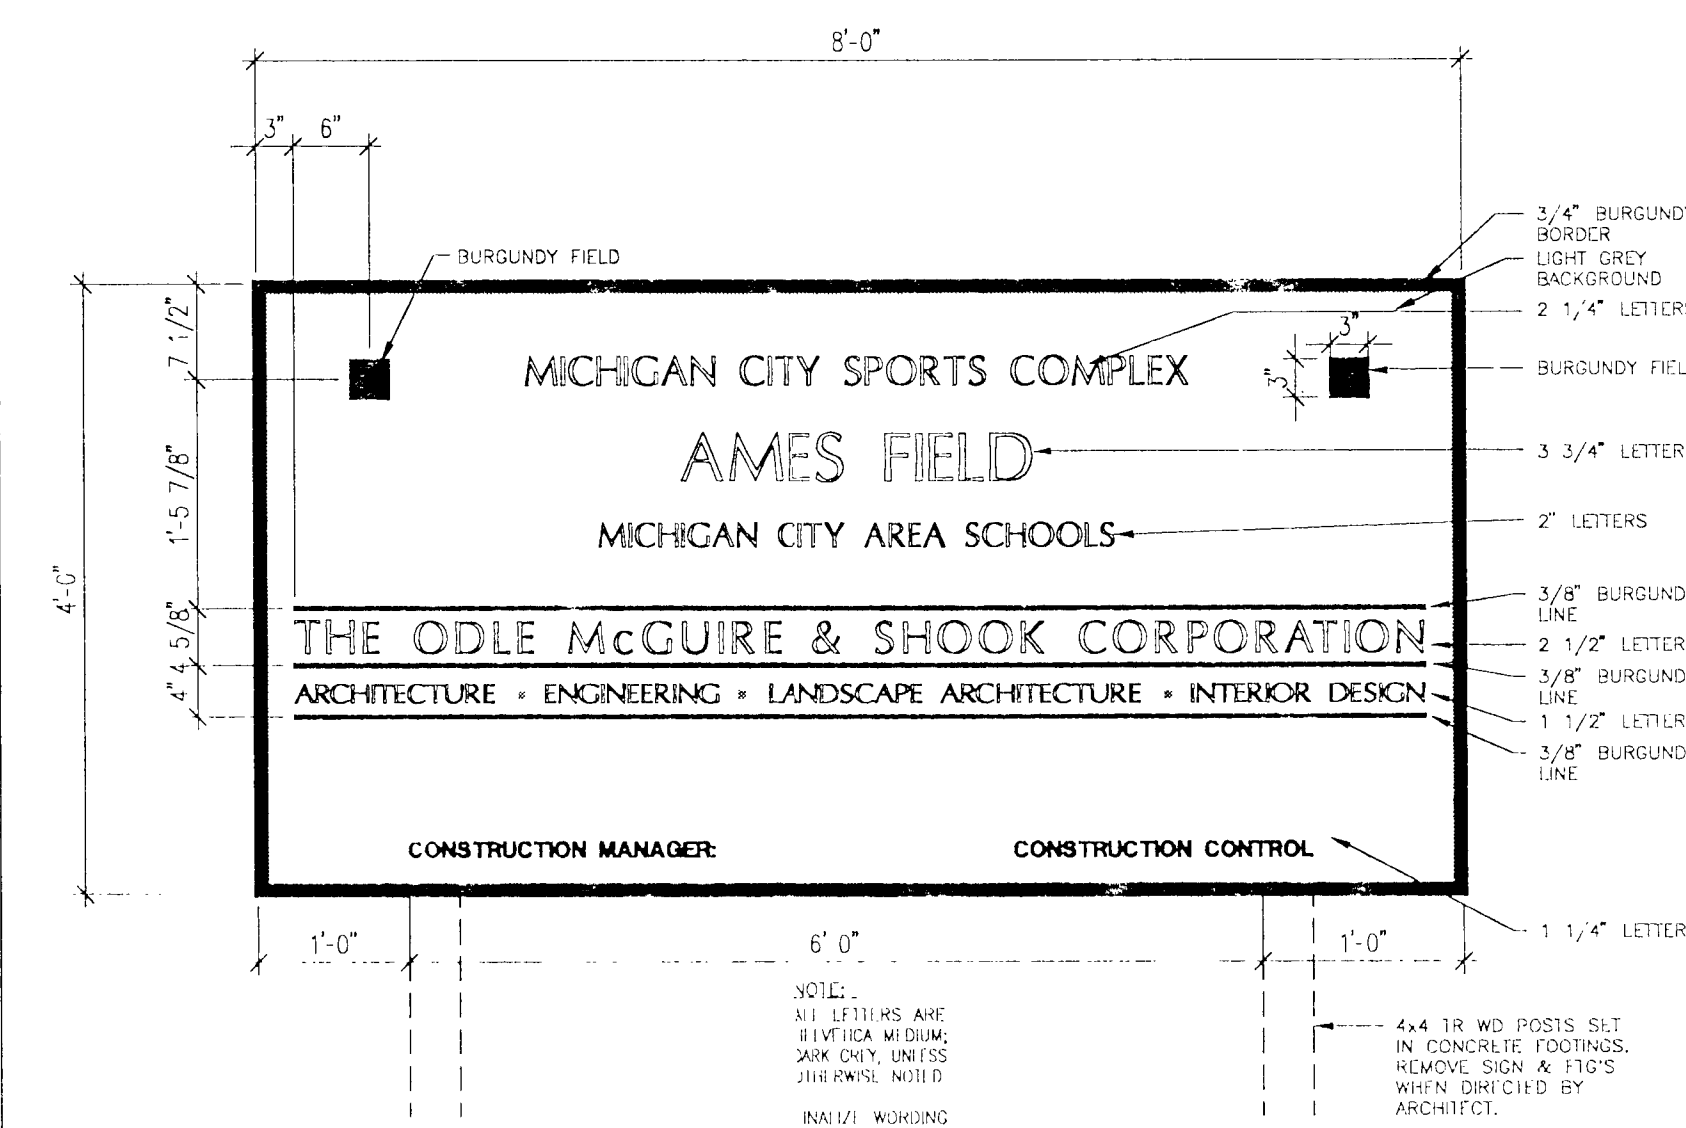

CERTIFIED

THE ODLE MCGUIRE & SHOOK CORPORATION
ARCHITECTURE • ENGINEERING • LANDSCAPE ARCHITECTURE • INTERIOR DESIGN
6786 NORTH STATE ROAD 37, POST OFFICE BOX 2149, BLOOMINGTON, INDIANA 47402, 817/876-2020
8275 ALLISON POINTE TRAIL, POST OFFICE BOX 50428, INDIANAPOLIS, INDIANA 46250, 317/842-0000

REVISIONS

© Copyright 1984 by THE ODLE MCGUIRE & SHOOK CORPORATION. Copyright includes architectural work, building design, plans, drawings, and specifications. Architectural work is the work of the firm as well as the property of the firm. Reproduction without written permission is prohibited.

MICHIGAN CITY SPORTS COMPLEX
AMES FIELD
MICHIGAN CITY, INDIANA

PROJECT NO. 93052


DATE MAY 31, 1994

drawn by: MRM

checked by: GJ

INDEX

E:\CIVIL\ENR\305261\00 05-01-94 19:42:27

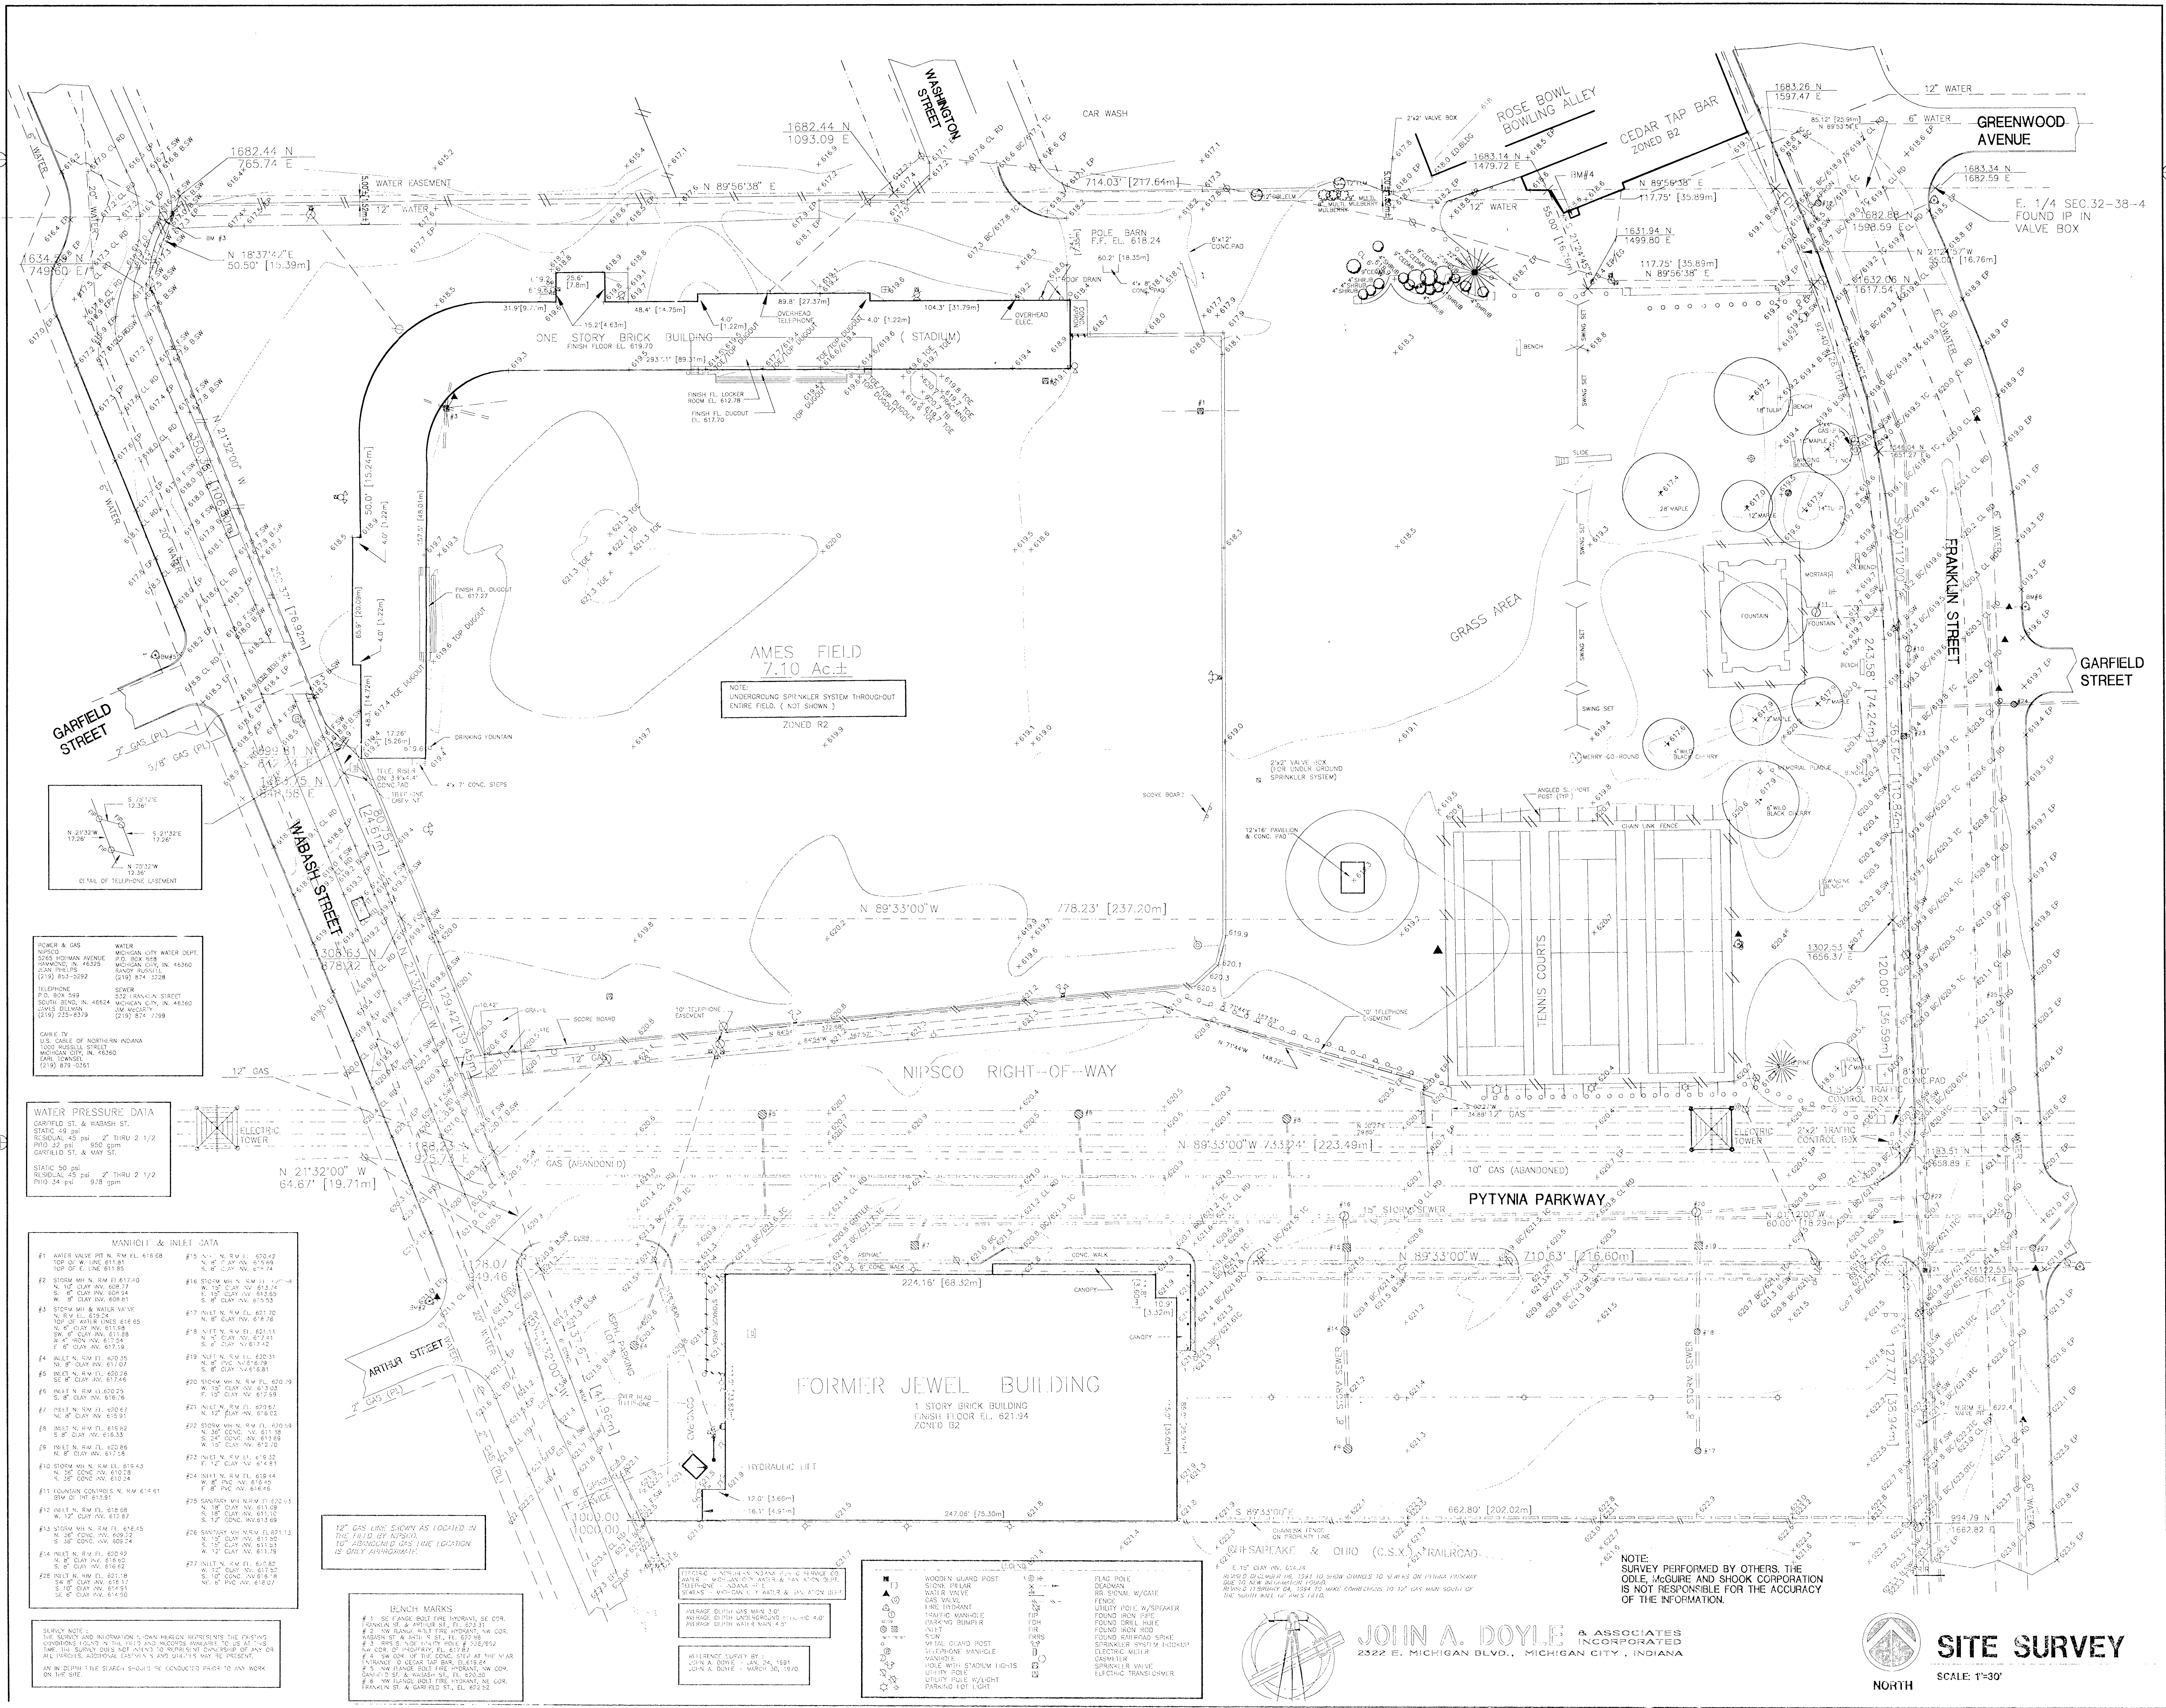

POWER & GAS
NIPSCO
3200 HIGHWAY AVENUE
HAWKINS, IN 46625
JAN TRIPLE
(219) 553-5292

WATER
MICHIGAN CITY WATER DEPT.
P.O. BOX 888
MICHIGAN CITY, IN 46360
RANDY HUSSELL
(219) 674-3228

TELEPHONE
P.O. BOX 599
SOUTH BEND, IN 46604
JAMES DILLMAN
(219) 255-6379

CABLE TV
U.S. CABLE OF NORTHERN INDIANA
1000 RUSSELL STREET
MICHIGAN CITY, IN 46360
CARL TOWNELL
(219) 678-0261

WATER PRESSURE DATA
GARFIELD ST. & WABASH ST.
STATIC 90 PSI
RESIDUAL 45 PSI @ 2" THRU 1 1/2"
DITD 24 PSI

STATIC 90 PSI
RESIDUAL 45 PSI @ 2" THRU 1 1/2"
DITD 24 PSI


MANHOLE & INLET DATA	
#1 WATER VALVE PRT N. RW EL. 616.68 TOP OF E. LINE 611.85	#15 N. RW EL. 620.42 S. RW EL. 619.74
#2 STORM MH N. RW EL. 617.40 S. RW EL. 616.82	#16 STORM MH N. RW EL. 617.40 S. RW EL. 616.82
#3 STORM MH & WATER VALVE TOP OF WATER LINES 616.65 S. RW EL. 616.82 SW. 6" CLAY INV. 611.88 W. 6" CLAY INV. 611.88	#17 INLET N. RW EL. 621.11 S. RW EL. 620.42
#4 INLET N. RW EL. 620.25 S. RW EL. 619.57	#18 INLET N. RW EL. 621.11 S. RW EL. 620.42
#5 INLET N. RW EL. 620.25 S. RW EL. 619.57	#19 INLET N. RW EL. 621.11 S. RW EL. 620.42
#6 INLET N. RW EL. 620.25 S. RW EL. 619.57	#20 INLET N. RW EL. 621.11 S. RW EL. 620.42
#7 INLET N. RW EL. 620.25 S. RW EL. 619.57	#21 INLET N. RW EL. 621.11 S. RW EL. 620.42
#8 INLET N. RW EL. 620.25 S. RW EL. 619.57	#22 INLET N. RW EL. 621.11 S. RW EL. 620.42
#9 INLET N. RW EL. 620.25 S. RW EL. 619.57	#23 INLET N. RW EL. 621.11 S. RW EL. 620.42
#10 STORM MH N. RW EL. 616.43 S. RW EL. 615.75	#24 INLET N. RW EL. 621.11 S. RW EL. 620.42
#11 FOUNTAIN CONTROLS N. RW EL. 619.61 S. RW EL. 618.93	#25 INLET N. RW EL. 621.11 S. RW EL. 620.42
#12 INLET N. RW EL. 618.45 S. RW EL. 617.77	#26 INLET N. RW EL. 621.11 S. RW EL. 620.42
#13 INLET N. RW EL. 618.45 S. RW EL. 617.77	#27 INLET N. RW EL. 621.11 S. RW EL. 620.42
#14 INLET N. RW EL. 618.45 S. RW EL. 617.77	#28 INLET N. RW EL. 621.11 S. RW EL. 620.42

12" GAS LINE SHOWN AS LOCATED IN
THE FIELD OF NIPSCO
12" ABANDONED GAS LINE LOCATION
IS ONLY APPROXIMATE.

BENCH MARKS
#1 SE FANG BOLT FIRE HYDRANT, SE COR.
#2 NW FANG BOLT FIRE HYDRANT, NW COR.
#3 REFS. N. RW EL. 621.11
#4 SW COR. OF THE CONC. SITE AT THE W. END
#5 NW FANG BOLT FIRE HYDRANT, NW COR.
#6 NW FANG BOLT FIRE HYDRANT, NW COR.
#7 NW FANG BOLT FIRE HYDRANT, NW COR.


REFERENCE SURVEY BY:
JOHN A. DOYLE & ASSOCIATES
MARCH 30, 1990

- WOODEN GUARD POST
 - STONE TIER
 - WATER VALVE
 - CONCRETE MANHOLE
 - WIRE INFRANT
 - AVG. DITCH W/ MAIN 4" D
 - AVG. DITCH UNDERGROUND 12" D 4"
 - AVG. DITCH UNDERGROUND 12" D 4"
- FLAG POLE
 - CEANMA
 - RR SIGNAL W/CAT
 - FENCE
 - UTILITY POLE W/SPEAKER
 - FOUND BRILL. POLE
 - FOUND RAILROAD SPIKE
 - FOUND RAILROAD SPIKE
 - SPRINKLER SYSTEM HOODUP
 - ELECTRIC METER
 - CASHEMER
 - SPRINKLER VALVE
 - ELECTRIC TRANSFORMER

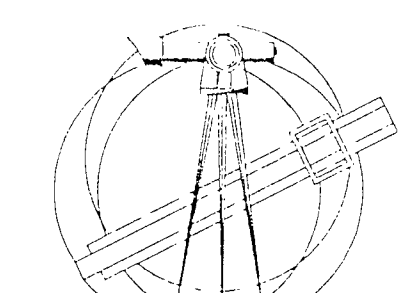

JOHN A. DOYLE & ASSOCIATES
2522 E. MICHIGAN BLVD., MICHIGAN CITY, INDIANA

NOTE:
SURVEY PERFORMED BY OTHERS. THE
ODLE, MCGUIRE & SHOOK CORPORATION
IS NOT RESPONSIBLE FOR THE ACCURACY
OF THE INFORMATION.

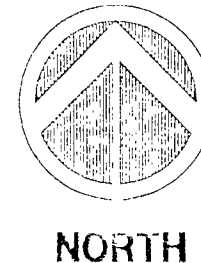

SITE SURVEY
SCALE: 1"=30'

CERTIFIED

THE ODLE MCGUIRE & SHOOK CORPORATION
ARCHITECTURE • ENGINEERING • LANDSCAPE ARCHITECTURE • INTERIOR DESIGN
ODLE, MCGUIRE & SHOOK CORPORATION
2522 E. MICHIGAN BLVD., MICHIGAN CITY, INDIANA 46360-2522
(219) 674-3228

REVISIONS


© Copyright 1994 by THE ODLE MCGUIRE & SHOOK CORPORATION. All rights reserved. No part of this publication may be reproduced, stored in a retrieval system, or transmitted, in any form or by any means, electronic, mechanical, photocopying, recording, or by any information storage and retrieval system, without the prior written permission of THE ODLE MCGUIRE & SHOOK CORPORATION.

MICHIGAN CITY SPORTS COMPLEX
AMES FIELD
MICHIGAN CITY, INDIANA

PROJECT NO. 93052
DATE: 31 MAY 1994

drawn by:
checked by:

L100
SITE SURVEY

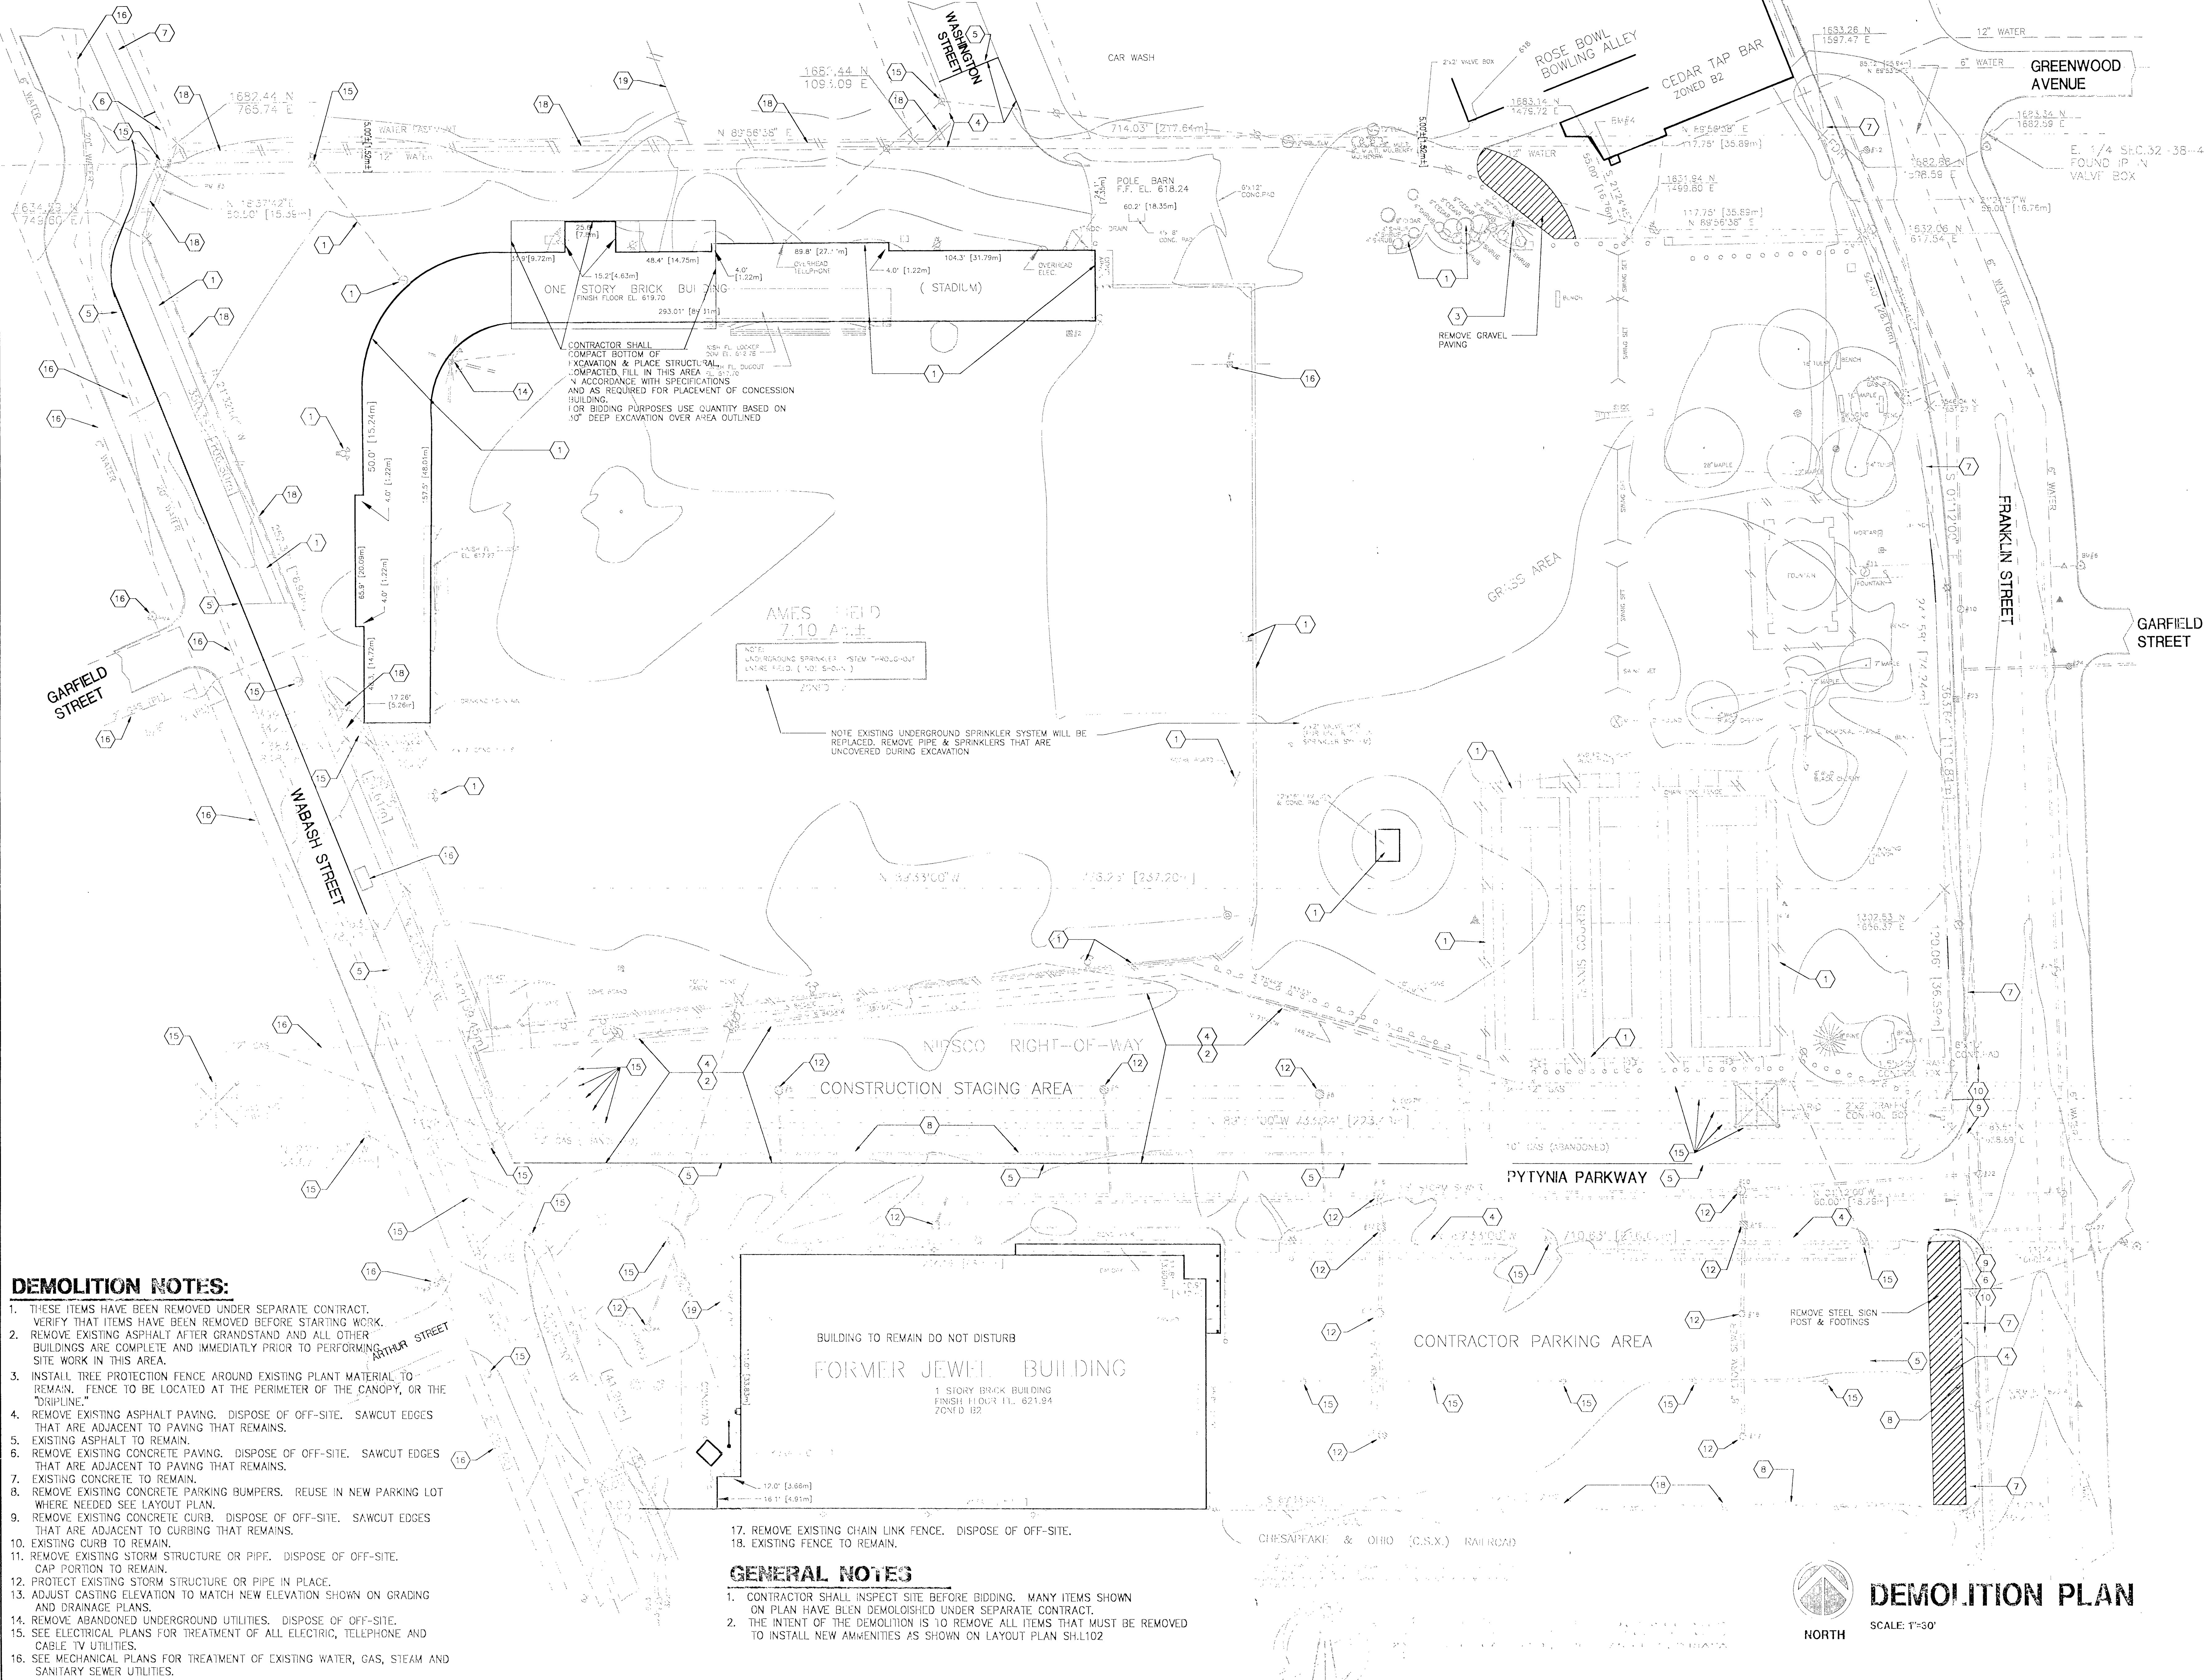

DEMOLITION NOTES:


1. THESE ITEMS HAVE BEEN REMOVED UNDER SEPARATE CONTRACT. VERIFY THAT ITEMS HAVE BEEN REMOVED BEFORE STARTING WORK.
2. REMOVE EXISTING ASPHALT AFTER GRANDSTAND AND ALL OTHER BUILDINGS ARE COMPLETE AND IMMEDIATELY PRIOR TO PERFORMING SITE WORK IN THIS AREA.
3. INSTALL TREE PROTECTION FENCE AROUND EXISTING PLANT MATERIAL TO REMAIN. FENCE TO BE LOCATED AT THE PERIMETER OF THE CANOPY, OR THE "DRIPLINE."
4. REMOVE EXISTING ASPHALT PAVING. DISPOSE OF OFF-SITE. SAWCUT EDGES THAT ARE ADJACENT TO PAVING THAT REMAINS.
5. EXISTING ASPHALT TO REMAIN.
6. REMOVE EXISTING CONCRETE PAVING. DISPOSE OF OFF-SITE. SAWCUT EDGES THAT ARE ADJACENT TO PAVING THAT REMAINS.
7. EXISTING CONCRETE TO REMAIN.
8. REMOVE EXISTING CONCRETE PARKING BUMPERS. REUSE IN NEW PARKING LOT WHERE NEEDED SEE LAYOUT PLAN.
9. REMOVE EXISTING CONCRETE CURB. DISPOSE OF OFF-SITE. SAWCUT EDGES THAT ARE ADJACENT TO CURBING THAT REMAINS.
10. EXISTING CURB TO REMAIN.
11. REMOVE EXISTING STORM STRUCTURE OR PIPE. DISPOSE OF OFF-SITE. CAP PORTION TO REMAIN.
12. PROTECT EXISTING STORM STRUCTURE OR PIPE IN PLACE.
13. ADJUST CASTING ELEVATION TO MATCH NEW ELEVATION SHOWN ON GRADING AND DRAINAGE PLANS.
14. REMOVE ABANDONED UNDERGROUND UTILITIES. DISPOSE OF OFF-SITE.
15. SEE ELECTRICAL PLANS FOR TREATMENT OF ALL ELECTRIC, TELEPHONE AND CABLE TV UTILITIES.
16. SEE MECHANICAL PLANS FOR TREATMENT OF EXISTING WATER, GAS, STEAM AND SANITARY SEWER UTILITIES.

BUILDING TO REMAIN DO NOT DISTURB
FORMER JEWEL BUILDING
1 STORY BRICK BUILDING
FINISH FLOOR E.L. 621.84
FOUND B2

17. REMOVE EXISTING CHAIN LINK FENCE. DISPOSE OF OFF-SITE.
18. EXISTING FENCE TO REMAIN.


GENERAL NOTES

1. CONTRACTOR SHALL INSPECT SITE BEFORE BIDDING. MANY ITEMS SHOWN ON PLAN HAVE BEEN DEMOLISHED UNDER SEPARATE CONTRACT.
2. THE INTENT OF THE DEMOLITION IS TO REMOVE ALL ITEMS THAT MUST BE REMOVED TO INSTALL NEW AMENITIES AS SHOWN ON LAYOUT PLAN SH.102

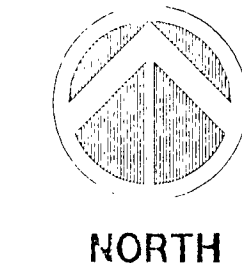

DEMOLITION PLAN

SCALE: 1"=30'

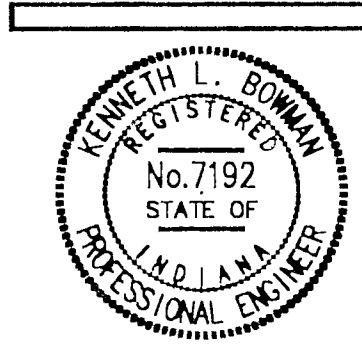

CERTIFIED

THE ODLE MCGUIRE & SHOOK CORPORATION
ARCHITECTURE • ENGINEERING • LANDSCAPE ARCHITECTURE • INTERIOR DESIGN
9765 NORTH STATE ROAD 37, POST OFFICE BOX 2146, BLOOMINGTON, INDIANA 47402, 812/876-2020
9775 ALLISON POINTE ROAD, POST OFFICE BOX 50464, INDIANAPOLIS, INDIANA 46250, 317/862-0880


REVISIONS

Copyright 1984 by THE ODLE MCGUIRE & SHOOK CORPORATION. Copyright includes architectural work, building design, plans or drawings, and specifications. Architectural work is the mental form and as the engineer meet and completion of same and materials in the design. Reproduction without written permission is prohibited.

MICHIGAN CITY SPORTS COMPLEX
AMES FIELD
MICHIGAN CITY, INDIANA

PROJECT NO. 93052
DATE: 31 MAY 1994
drawn by: SMR
checked by: BWR

L101
DEMOLITION PLAN

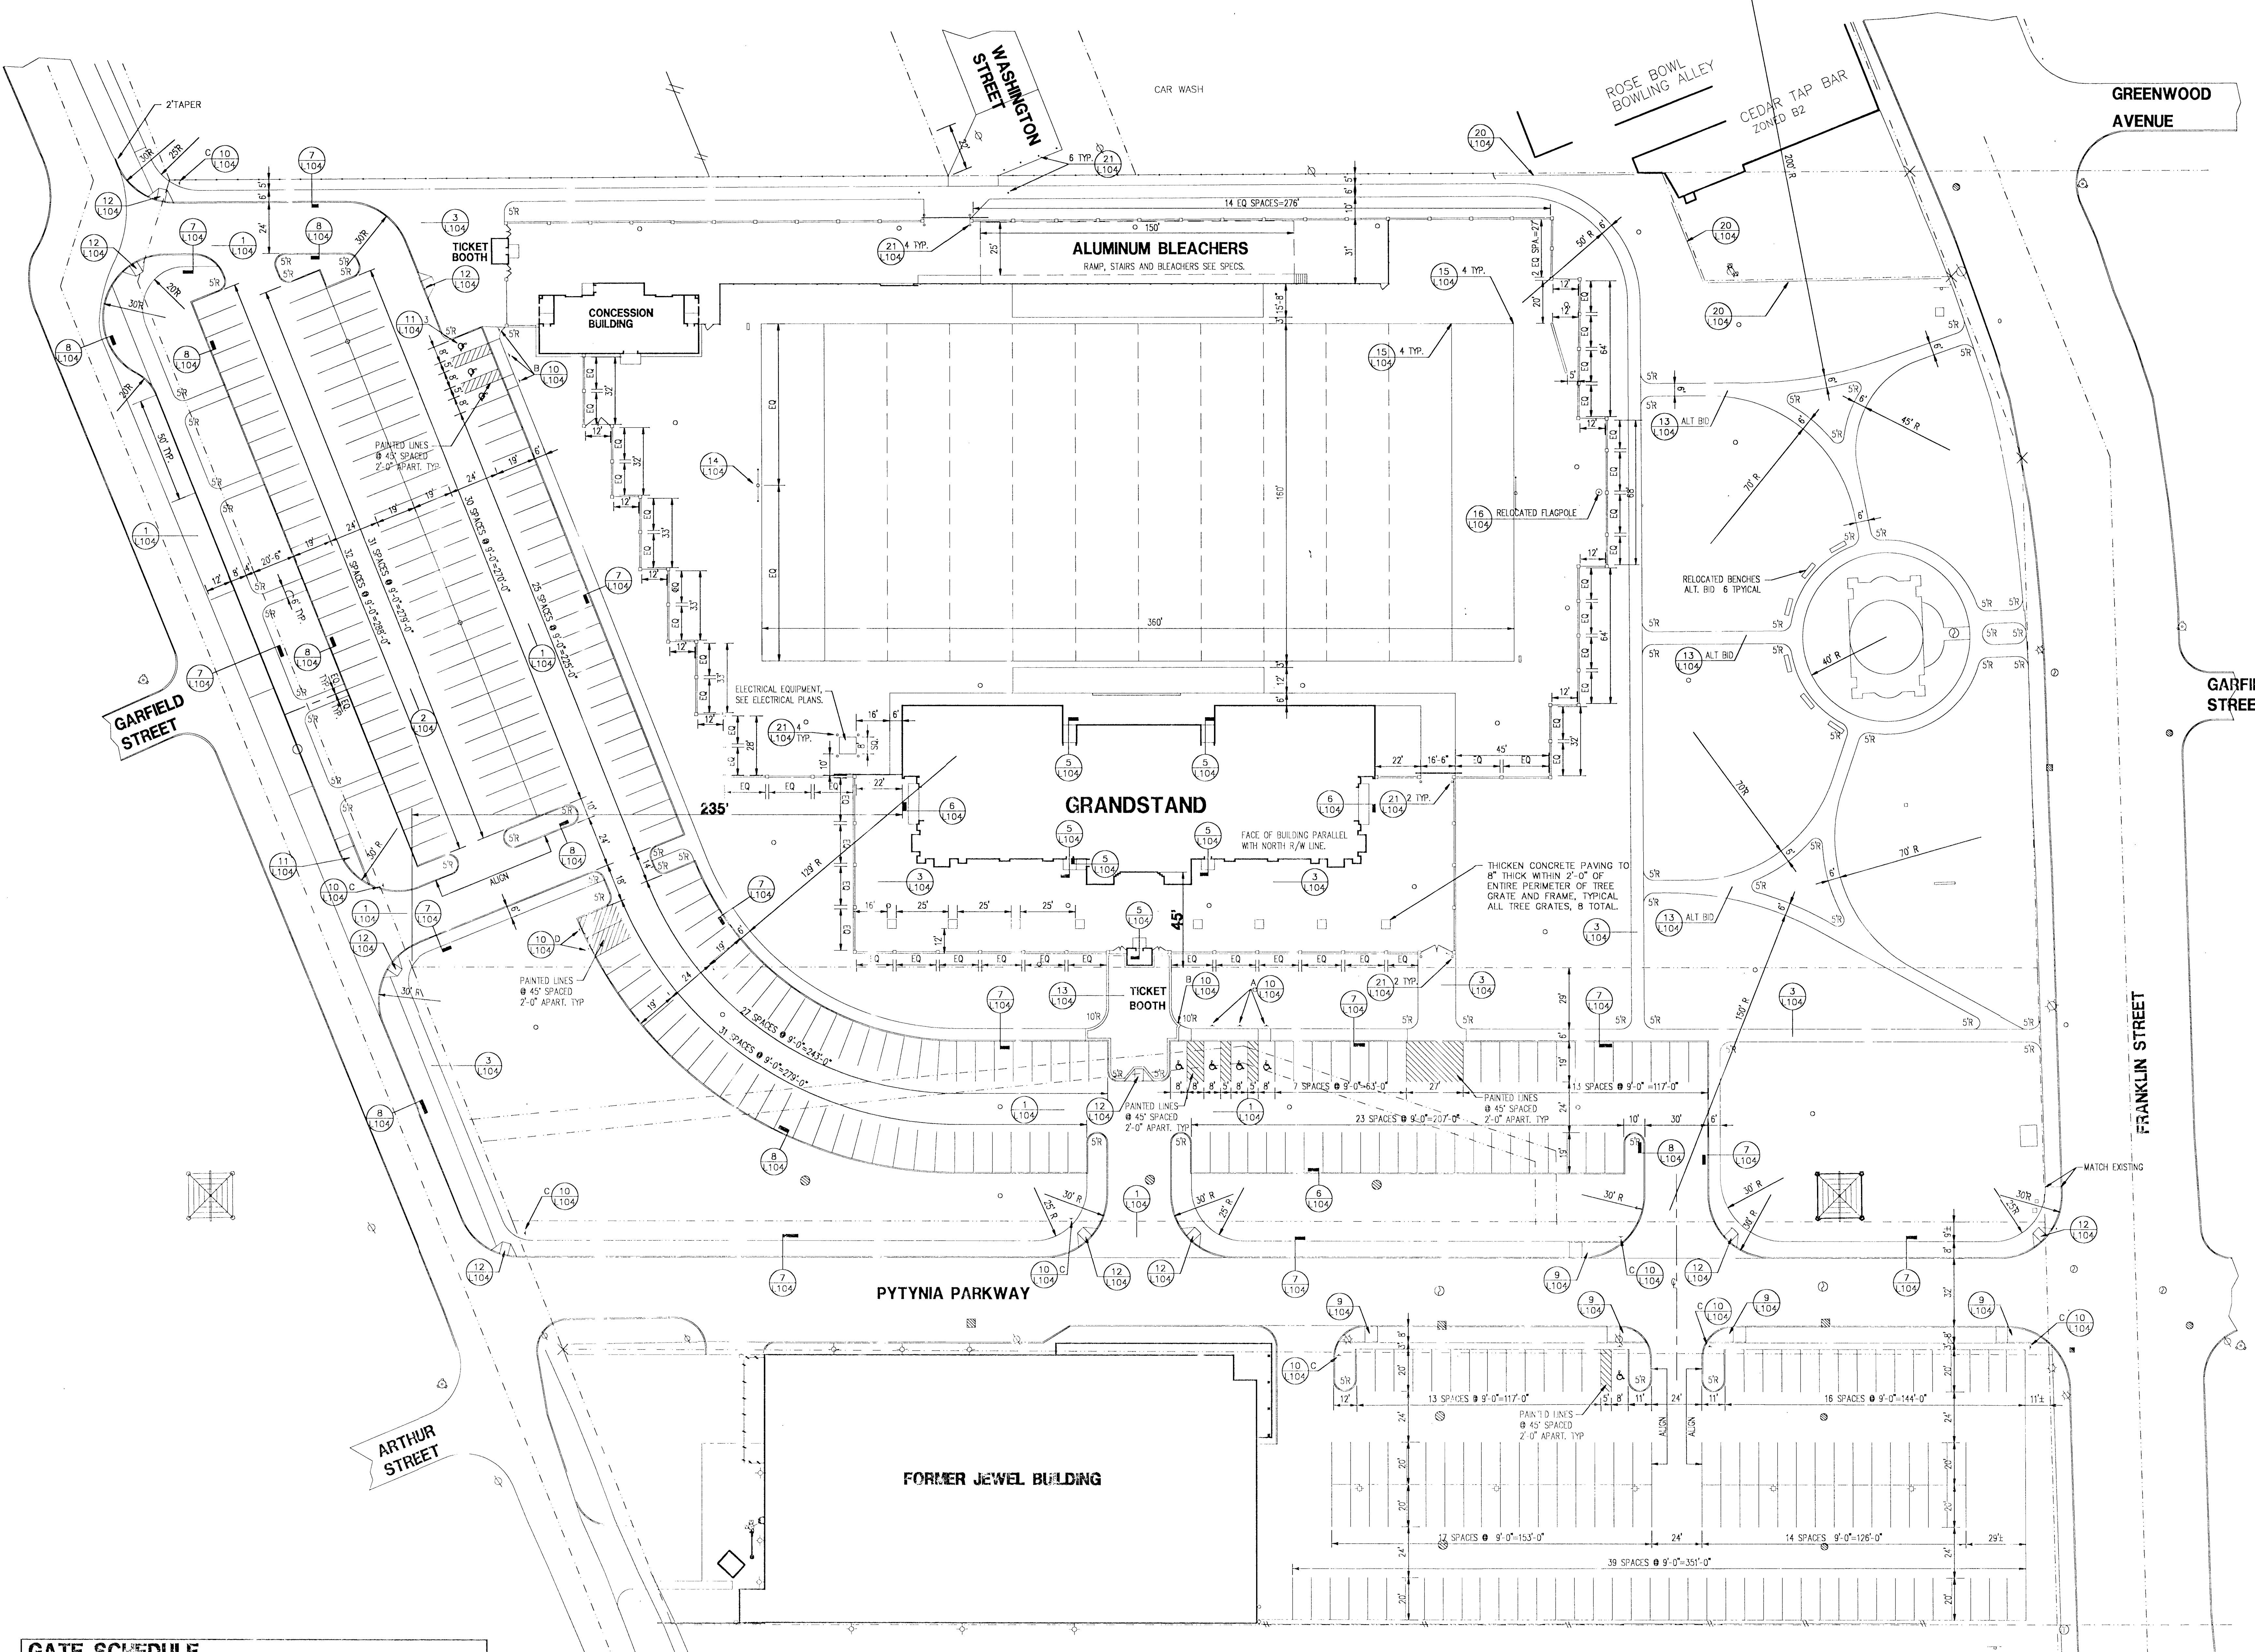

GATE SCHEDULE				
KEY	GATE MATERIAL	GATE TYPE	GATE HEIGHT	GATE OPENING
D	PVC COATED CHAINLINK	CANTILEVERED	8'	22'
F	PVC COATED CHAINLINK	CANTILEVERED	4'	16'
F	PVC COATED CHAINLINK	CANTILEVERED	8'	16'
G	PVC COATED CHAINLINK	SWINGING SINGLE	4'	4'
H	ORNAMENTAL PICKET	SWINGING DOUBLE	8'	16'
I	ORNAMENTAL PICKET	SWINGING DOUBLE	8'	6'
J	ORNAMENTAL PICKET	SWINGING DOUBLE	8'	12'

FENCE SCHEDULE		
KEY	FENCE MATERIAL	FENCE HEIGHT
A	PVC COATED CHAINLINK	4'
B	PVC COATED CHAINLINK	8'
C	ORNAMENTAL PICKET	8'

LAYOUT PLAN
 NORTH
 SCALE: 1"=30'

CERTIFIED

THE ODLE MCGUIRE & SHOOK CORPORATION
 ARCHITECTURE • ENGINEERING • LANDSCAPE ARCHITECTURE • INTERIOR DESIGN
 6765 NORTH STATE ROAD 371, POST OFFICE BOX 2749, BLOOMINGTON, INDIANA 47402, 817/876-2020
 8295 ALISON FOUNTAIN TRAIL, POST OFFICE BOX 30468, INDIANAPOLIS, INDIANA 46250, 317/542-0800

REVISIONS

© Copyright 1994 by THE ODLE MCGUIRE & SHOOK CORPORATION. Copyright includes architectural work, landscape design, plans or drawings, and specifications. Architectural work is the overall form as well as the arrangement and composition of space and elements in the design. Reproduction without written permission is prohibited.


MICHIGAN CITY SPORTS COMPLEX

AMES FIELD


MICHIGAN CITY, INDIANA

PROJECT NO. 93052
DATE: 31 MAY 1994
drawn by: SMR
checked by: BWR

L102
 LAYOUT PLAN

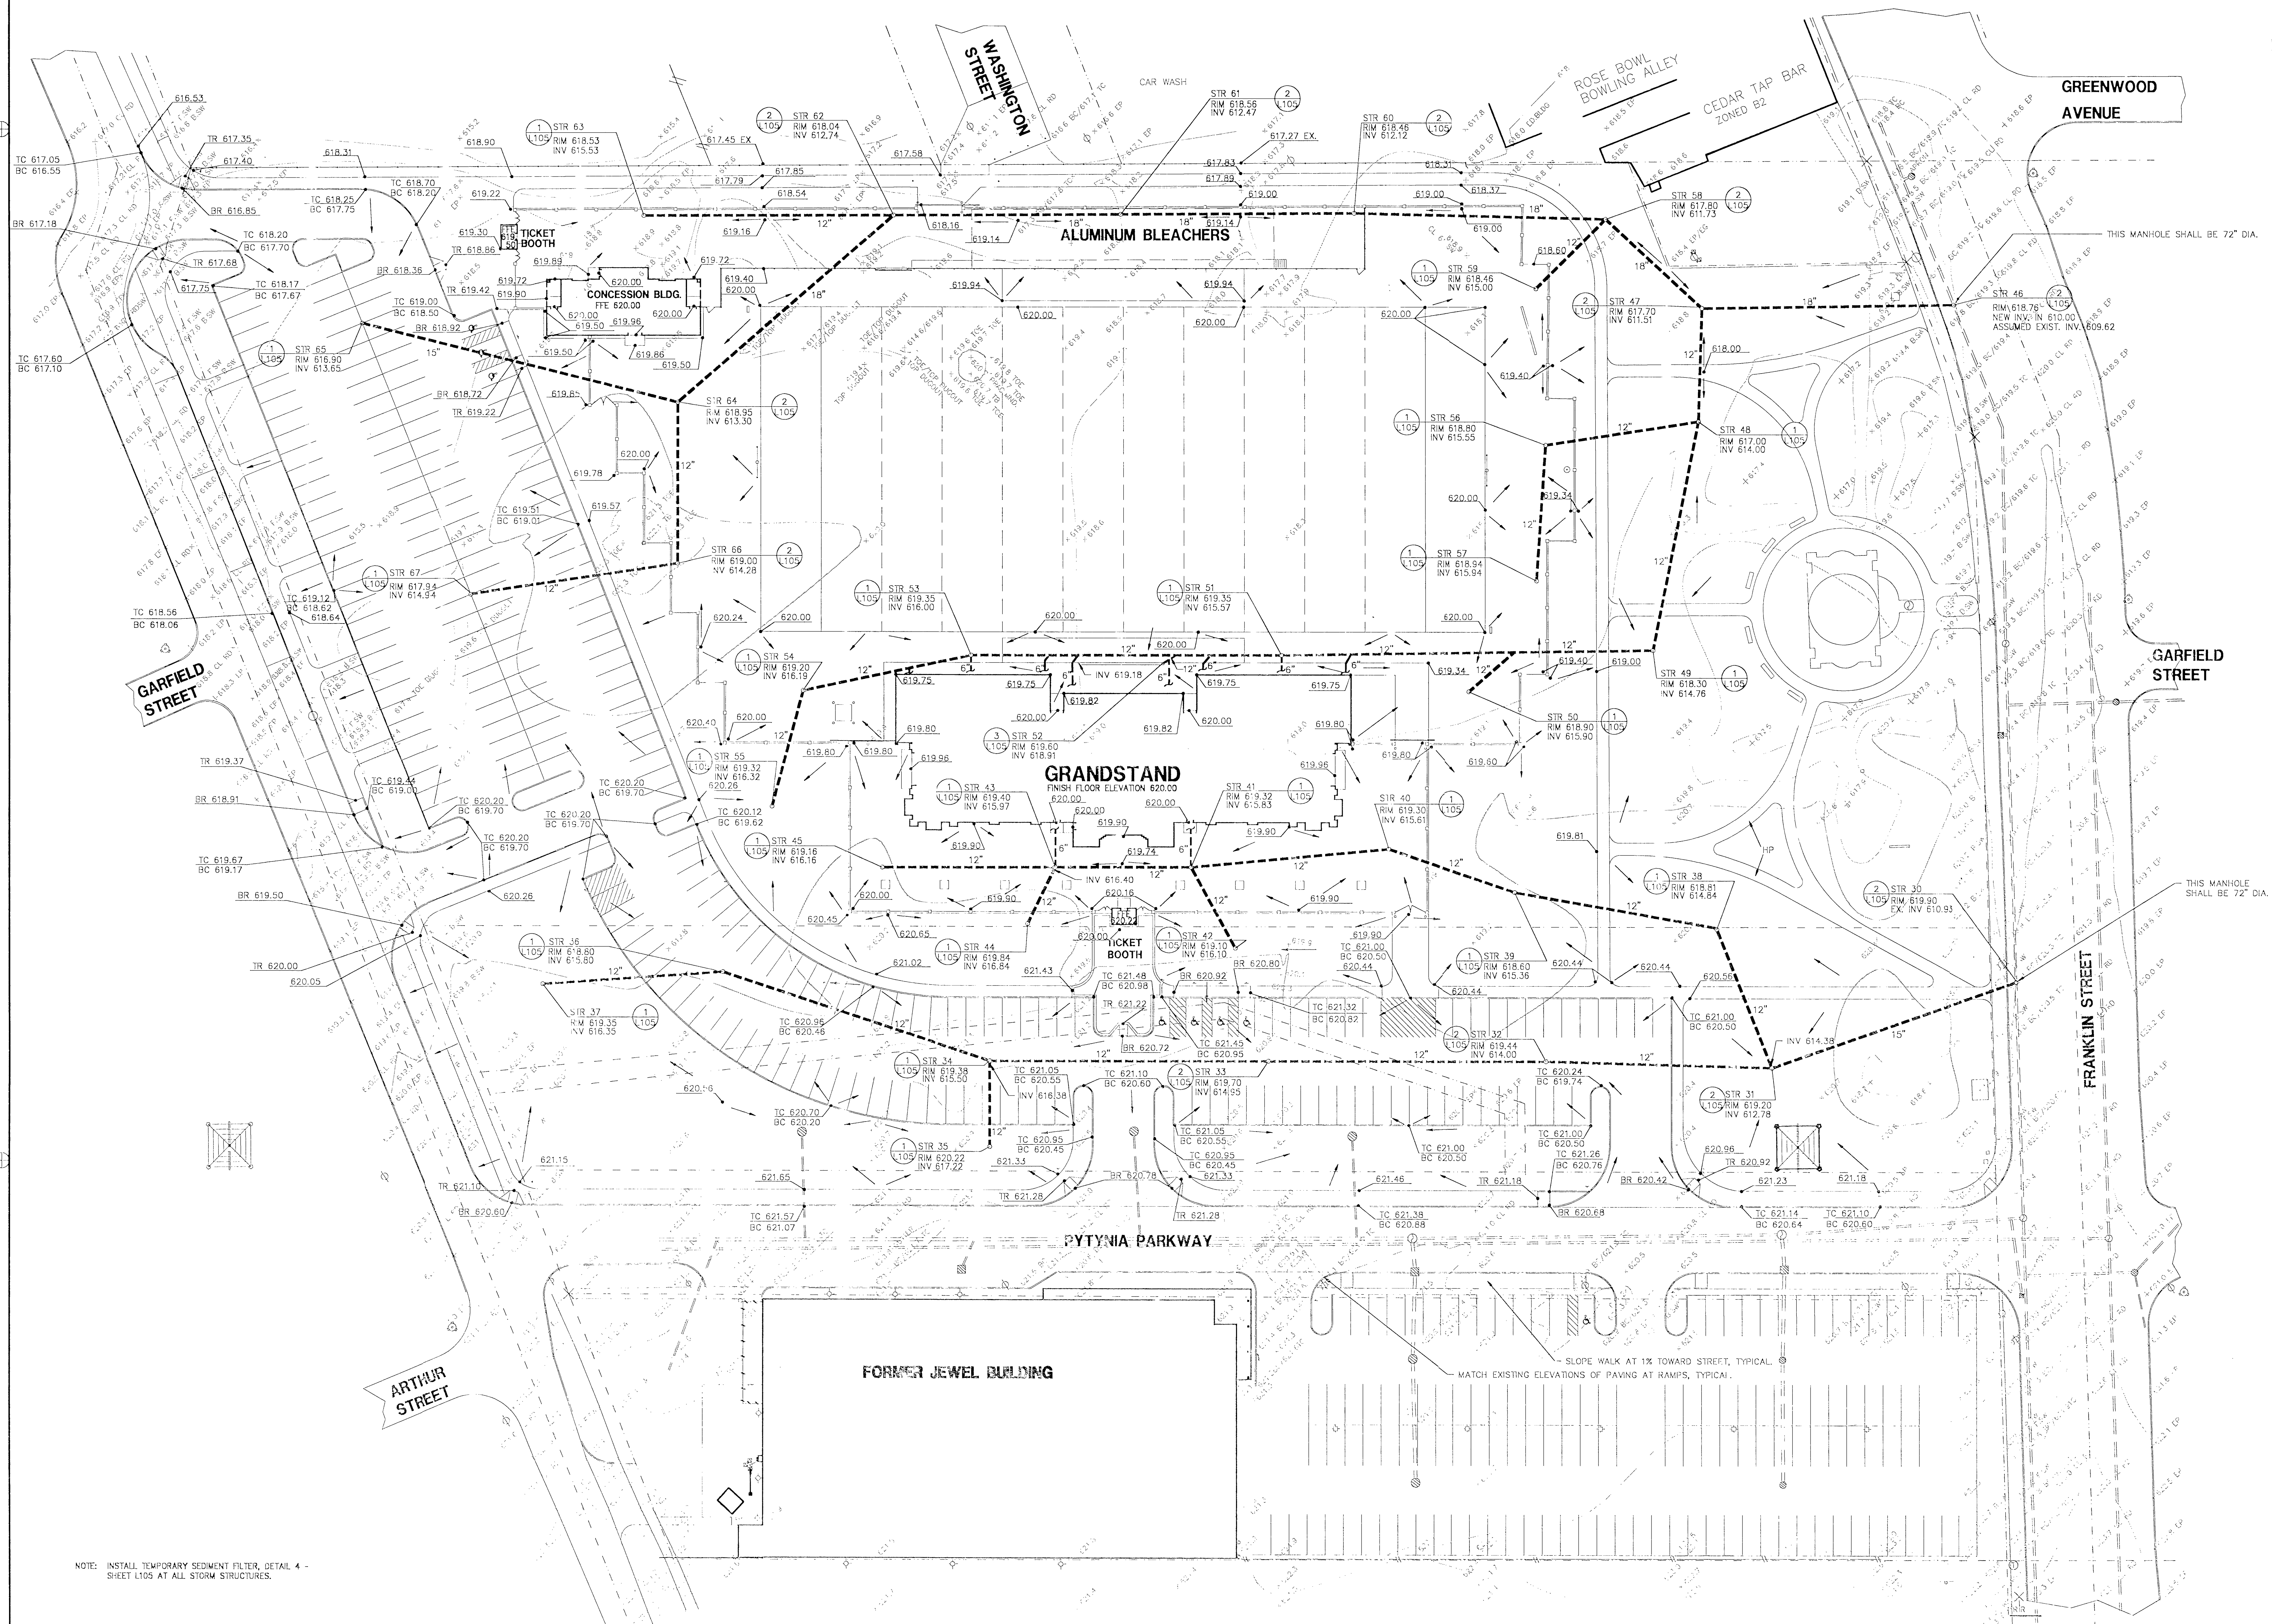


NOTE: INSTALL TEMPORARY SEDIMENT FILTER, DETAIL 4 - SHEET L105 AT ALL STORM STRUCTURES.

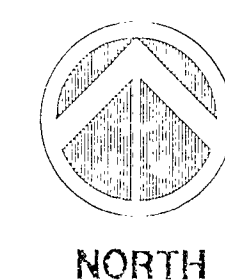

GRADING AND DRAINAGE PLAN

SCALE: 1"=30'

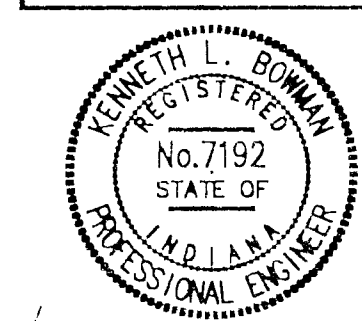

CERTIFIED

THE ODL McGUIRE & SHOOK CORPORATION
ARCHITECTURE • ENGINEERING • LANDSCAPE ARCHITECTURE • INTERIOR DESIGN


REVISIONS

© Copyright 1984 by THE ODL McGUIRE & SHOOK CORPORATION. Copyright includes architectural work, building design, plans or drawings, and specifications. Architectural work is the overall form as well as the arrangement and composition of space and elements in the design. Reproduction without written permission is prohibited.

MICHIGAN CITY SPORTS COMPLEX
AMES FIELD
MICHIGAN CITY, INDIANA

PROJECT NO. 93052
DATE: 31 MAY 1984
drawn by: SMR
checked by: BWR


L103
GRADING AND DRAINAGE PLAN

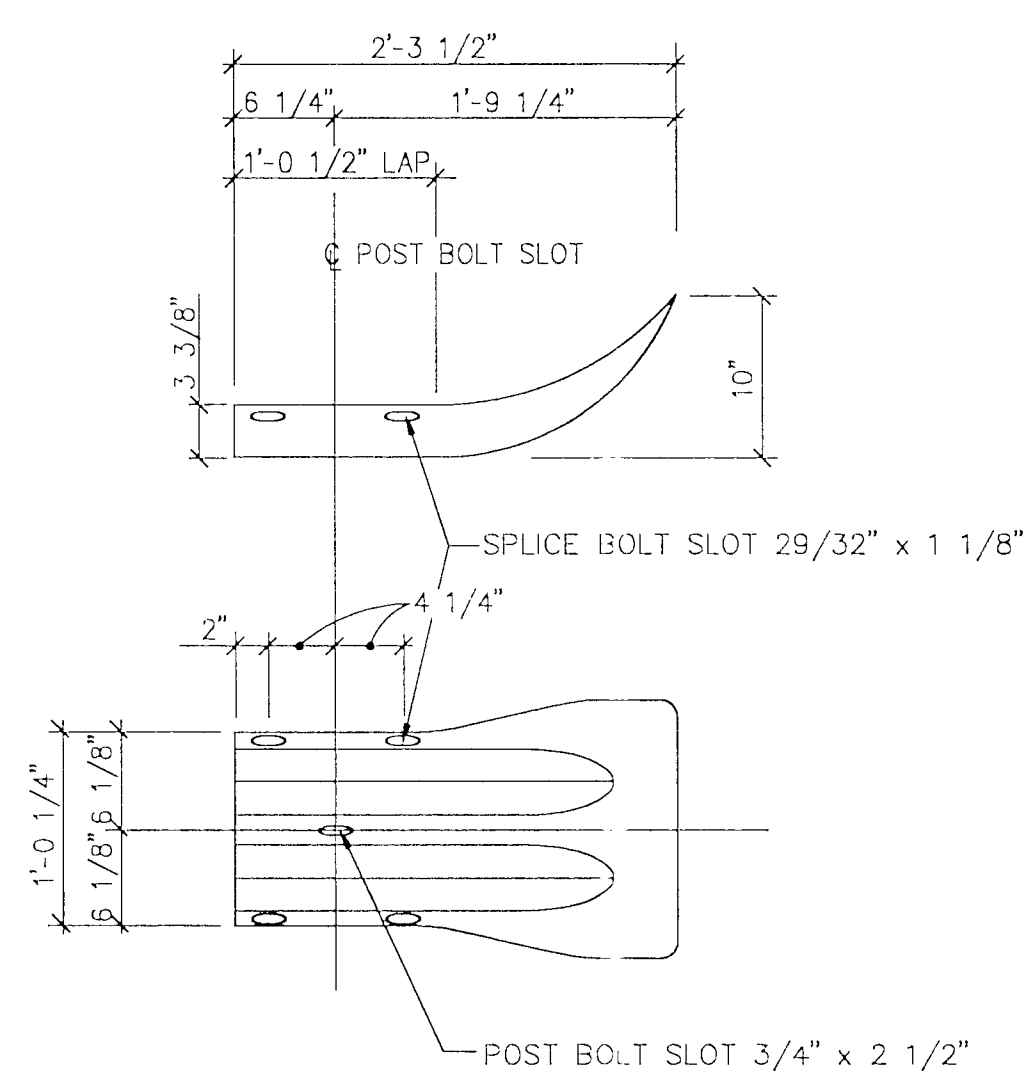

CURVED TERMINAL END

NO SCALE


19
L104

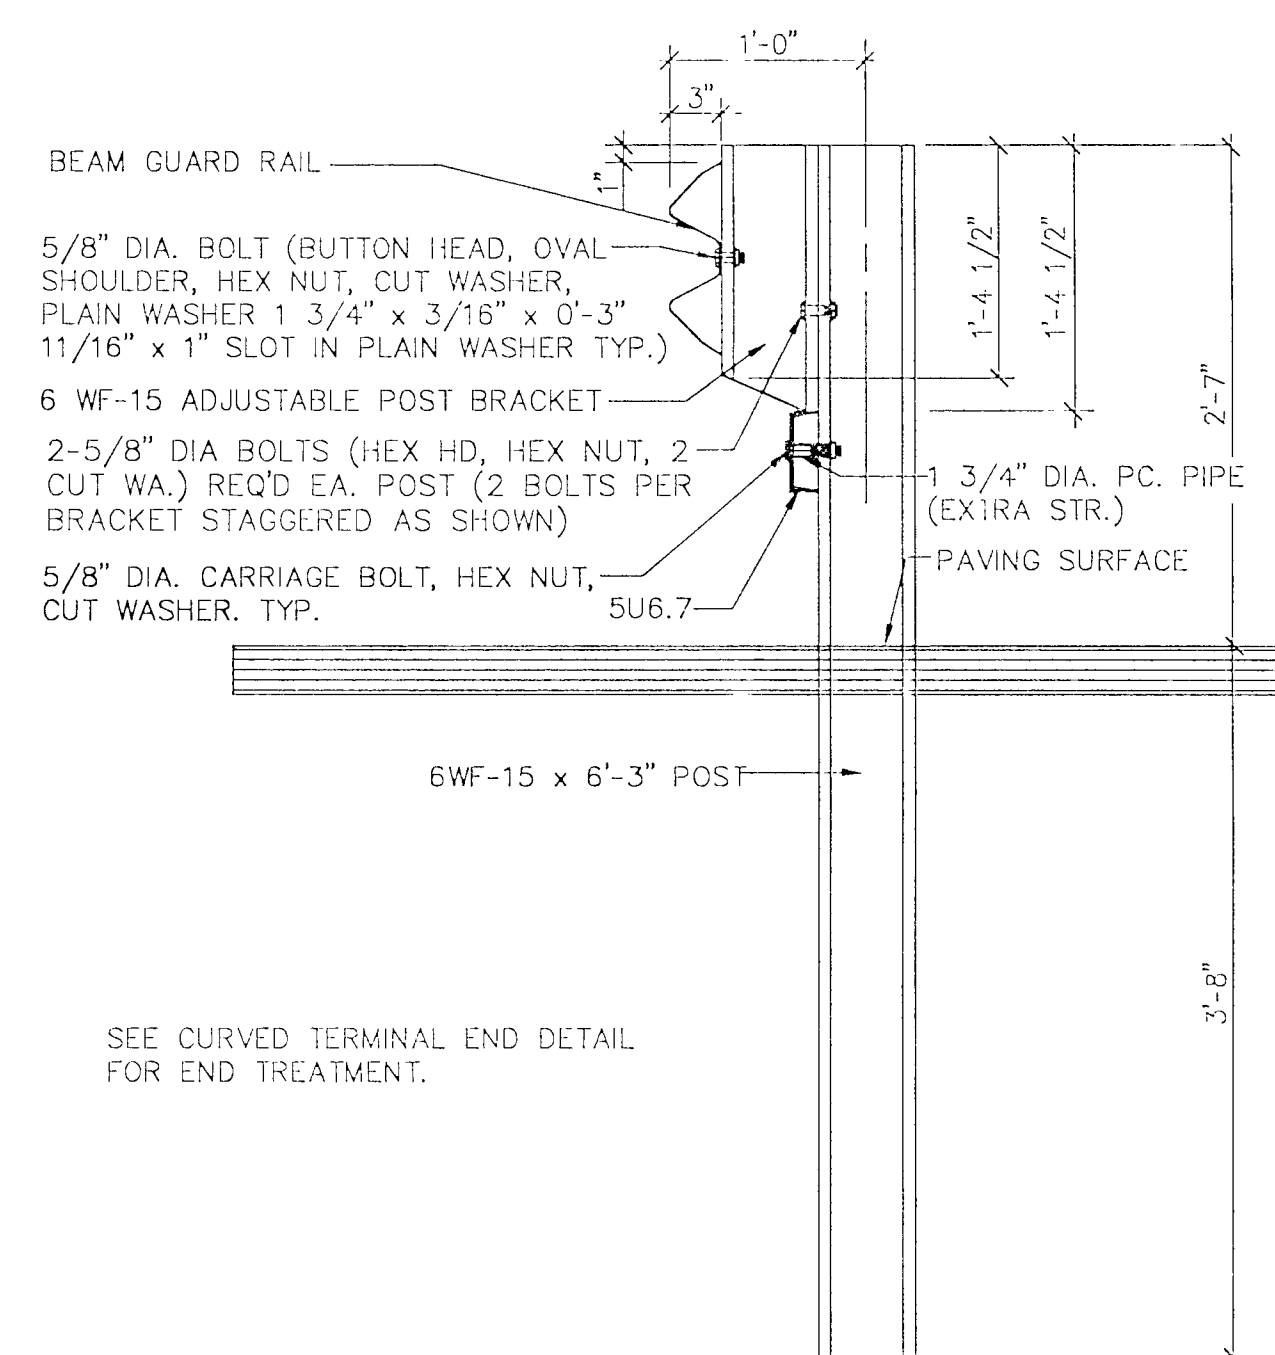

GUARD RAIL DETAIL

NO SCALE


20
L104

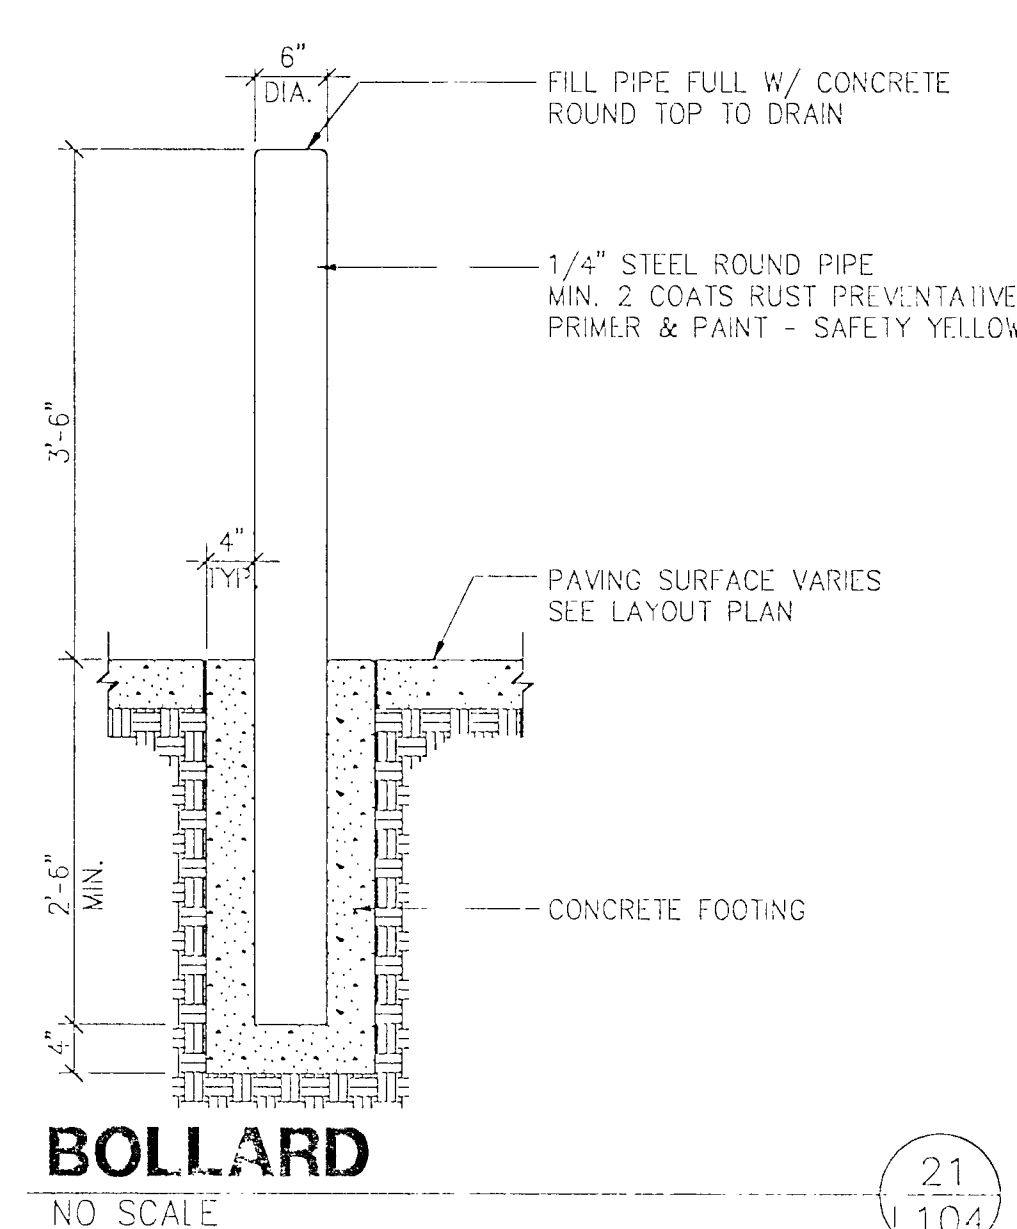

BOLLARD

NO SCALE


21
L104

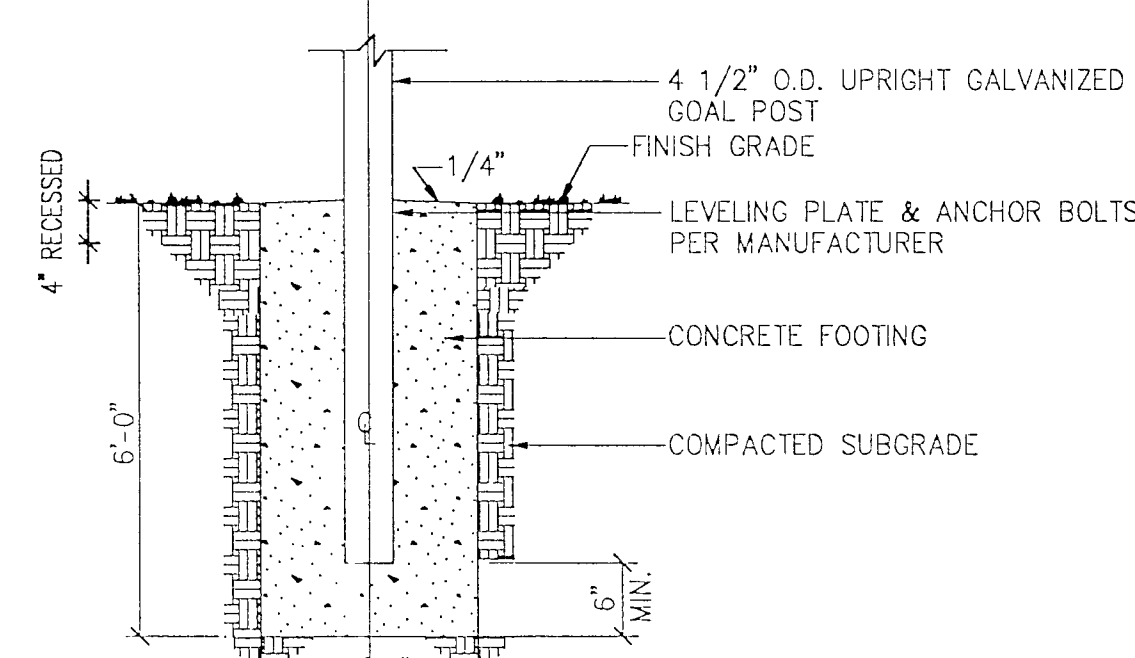

GOAL POST FOOTING

NO SCALE


14
L104

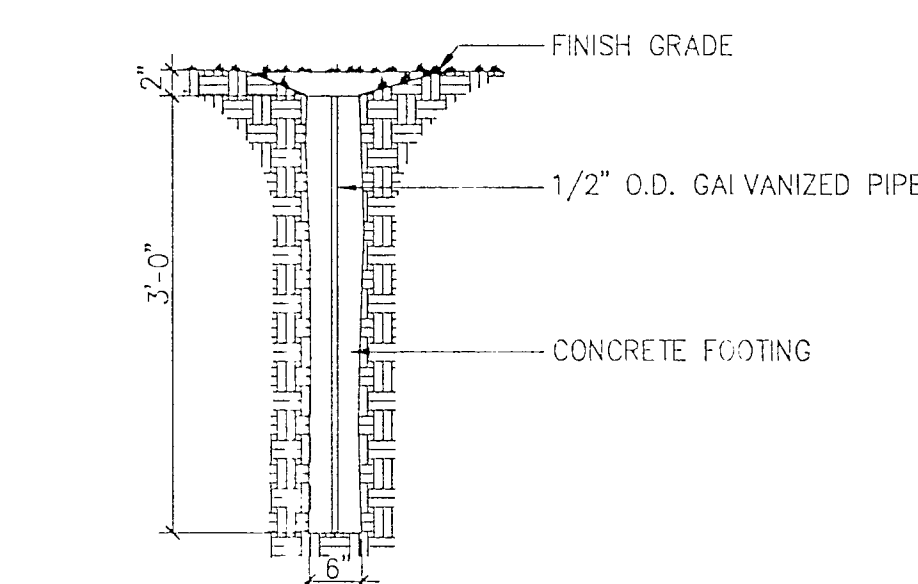

CORNER MARKER

NO SCALE


15
L104

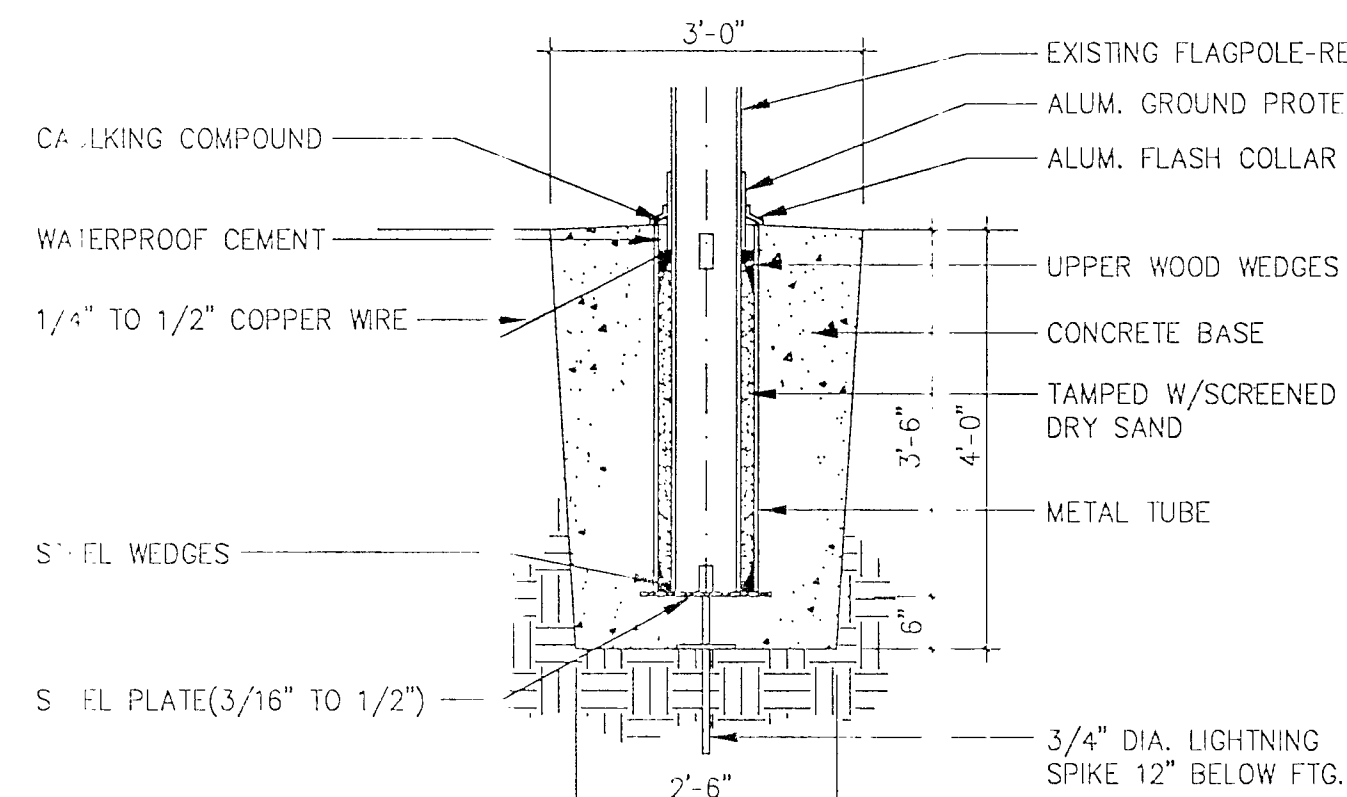

FLAGPOLE BASE DETAIL

NO SCALE


16
L104

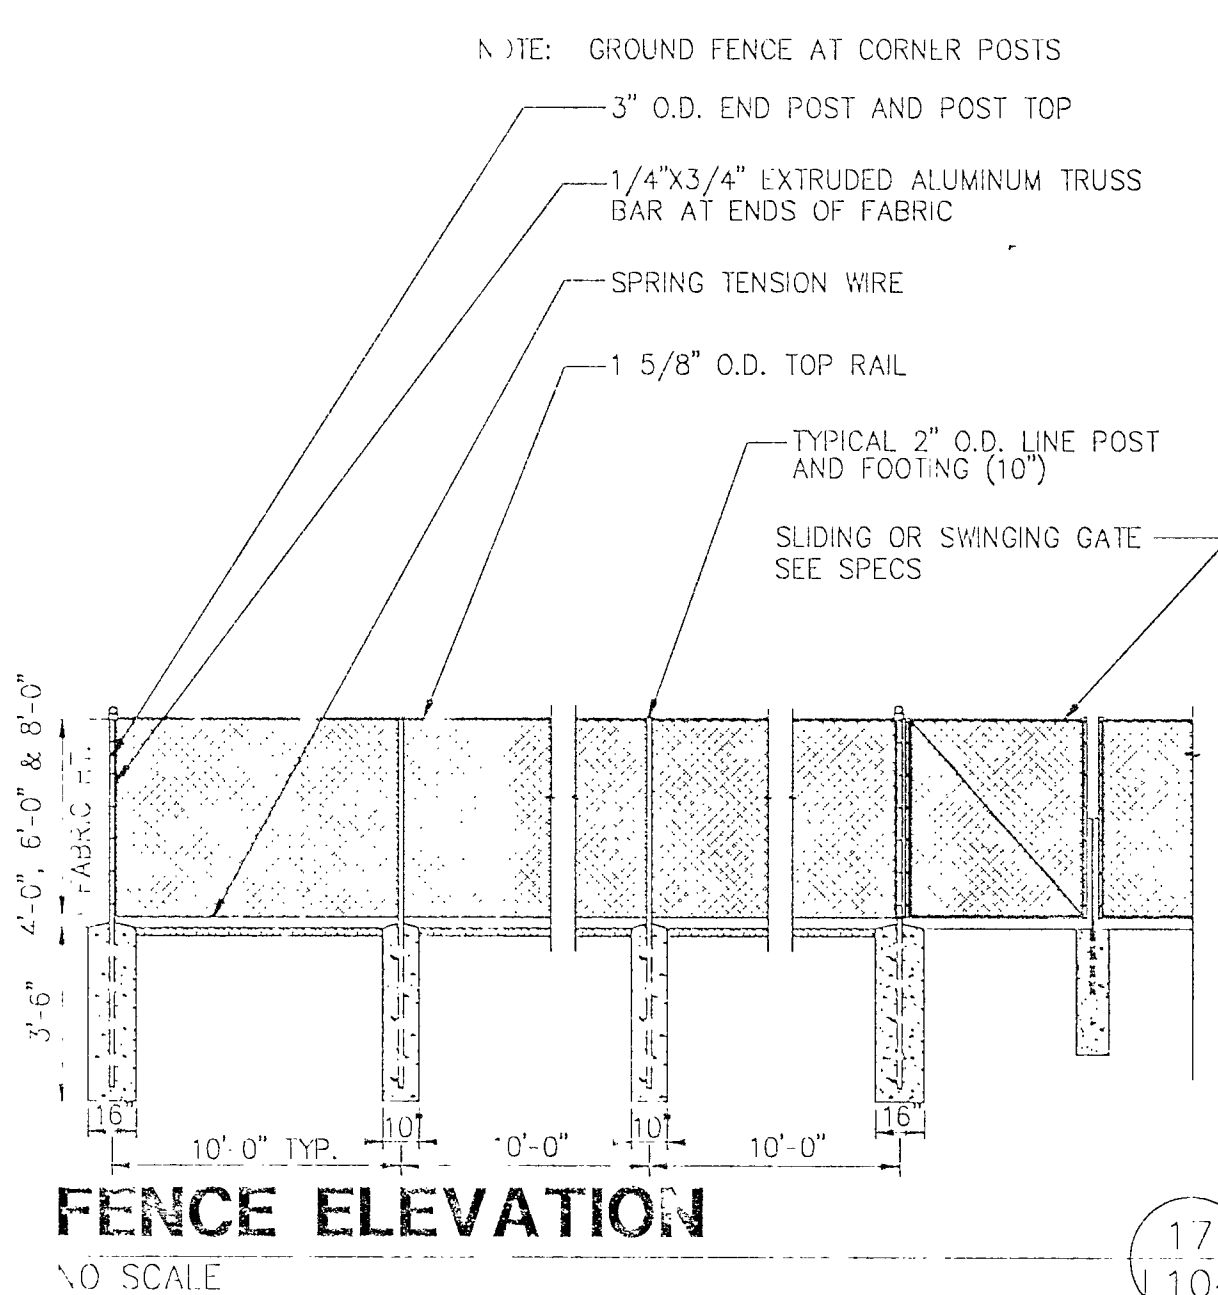

FENCE ELEVATION

NO SCALE


17
L104

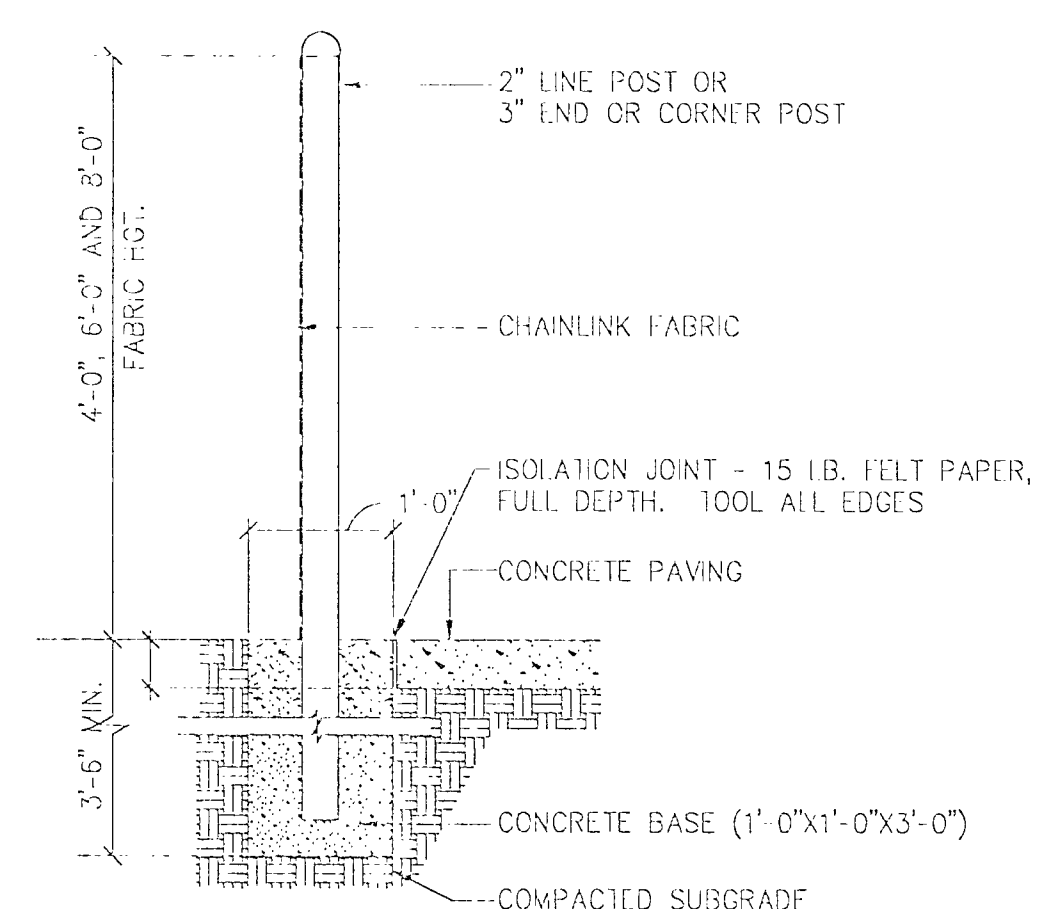

FENCE POST DETAIL

NO SCALE


18
L104

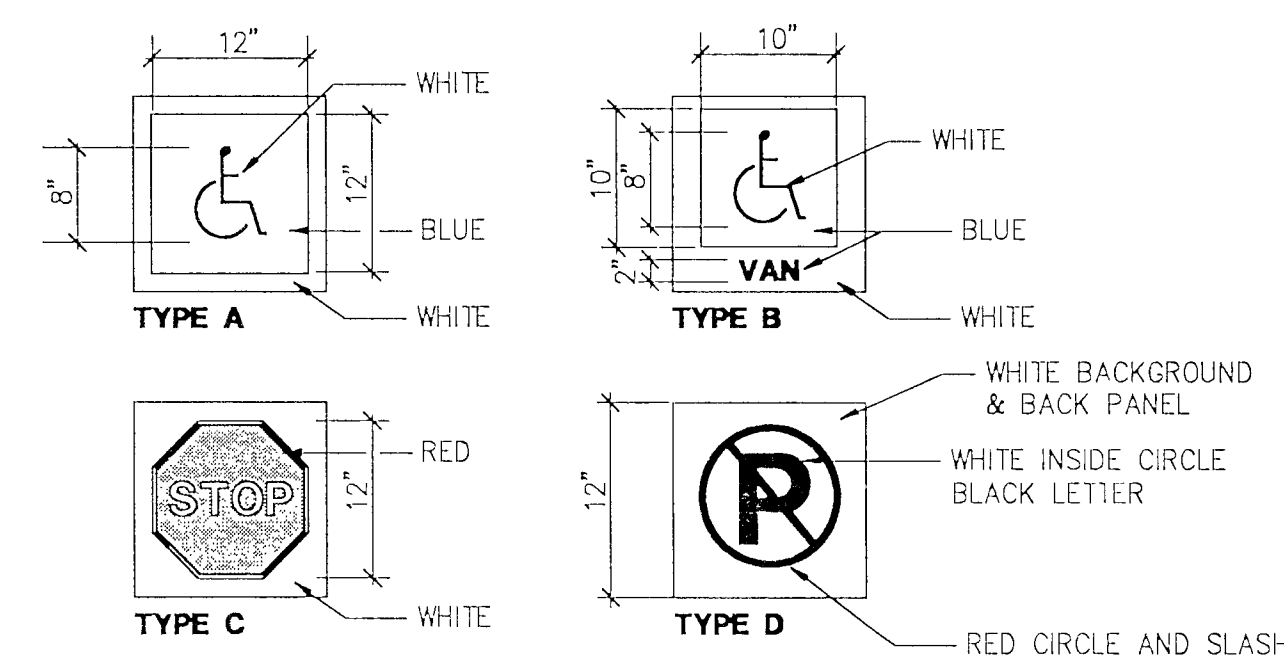

SIGN DETAILS

NO SCALE


10
L104

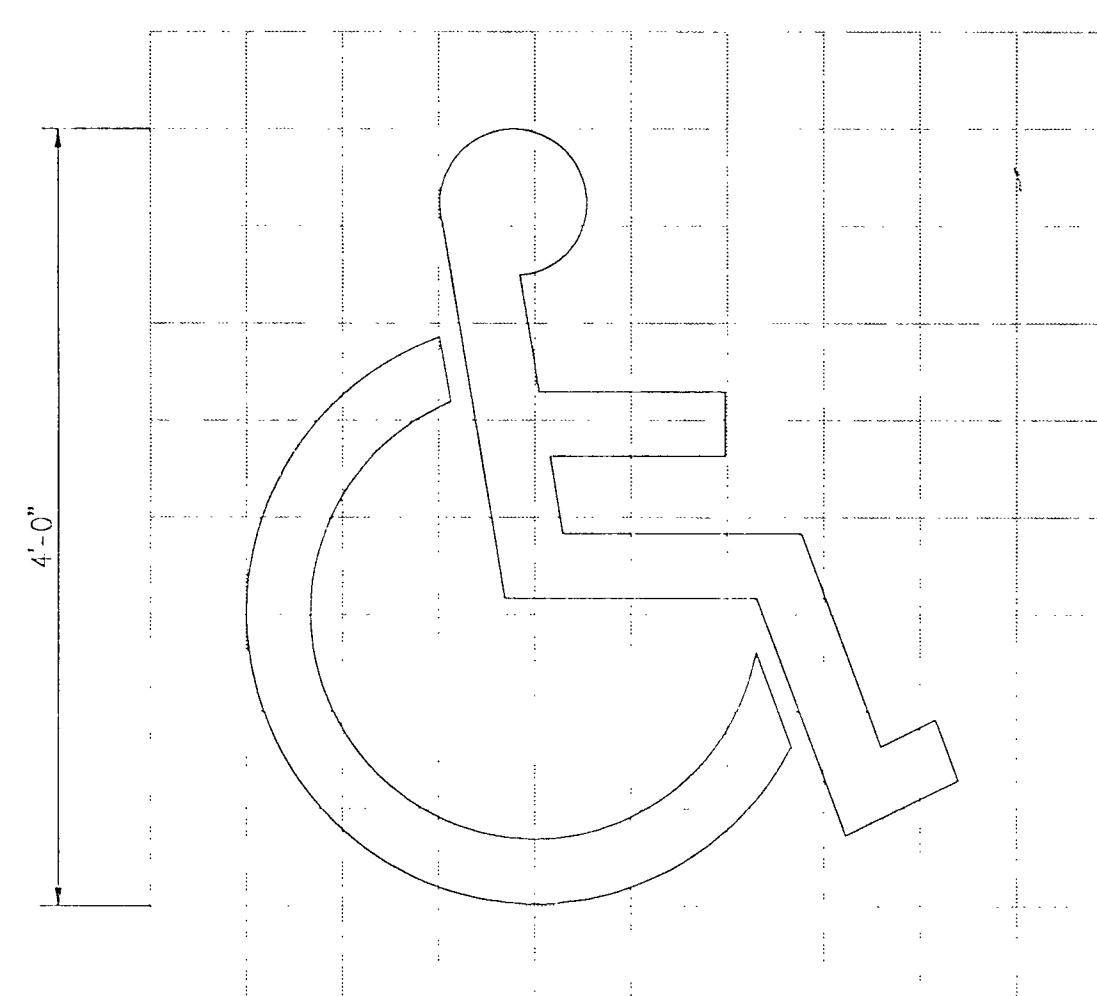

HANDICAP PAVEMENT MARKING

NO SCALE


11
L104

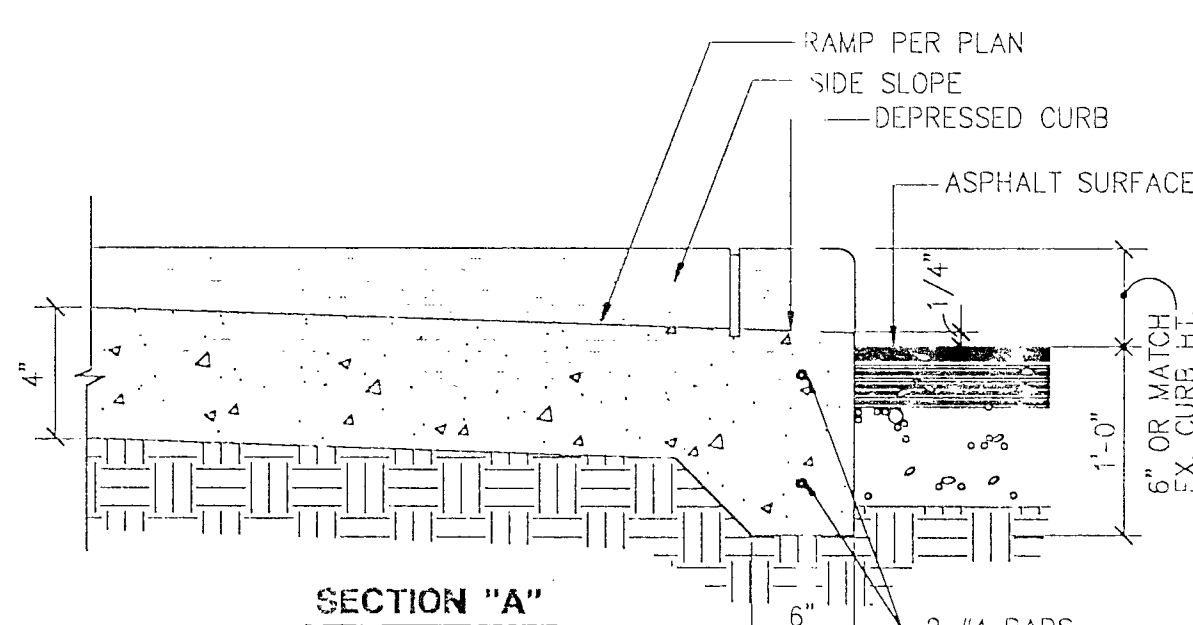

CONCRETE CURB

NO SCALE


8
L104

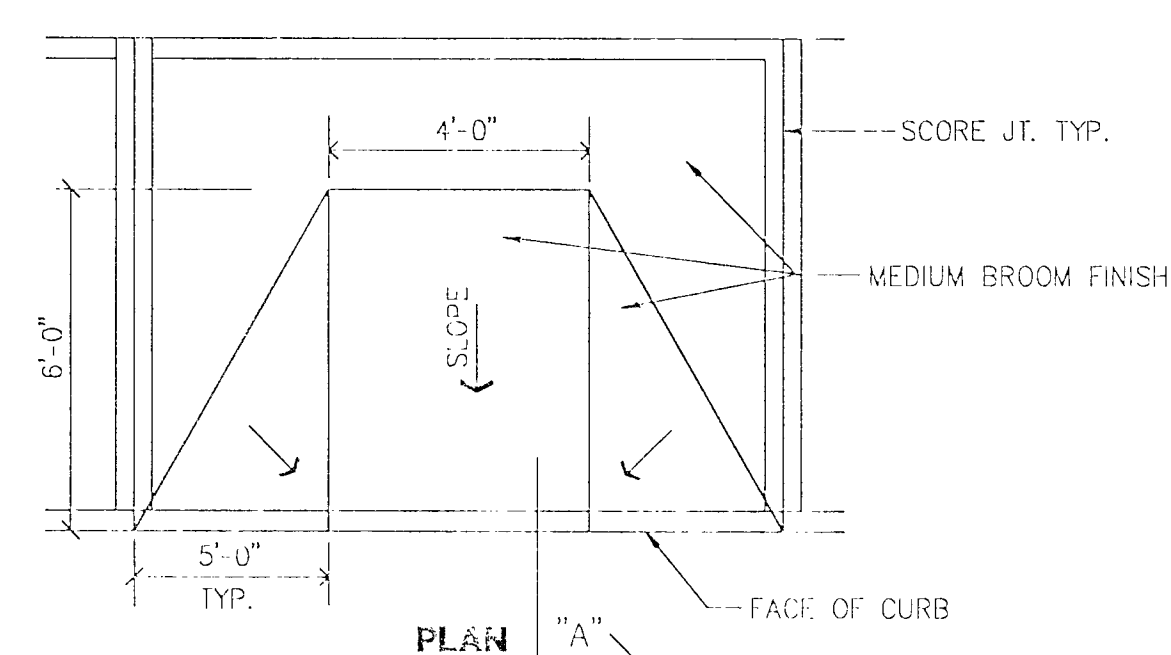

HANDICAP RAMP

NO SCALE


12
L104

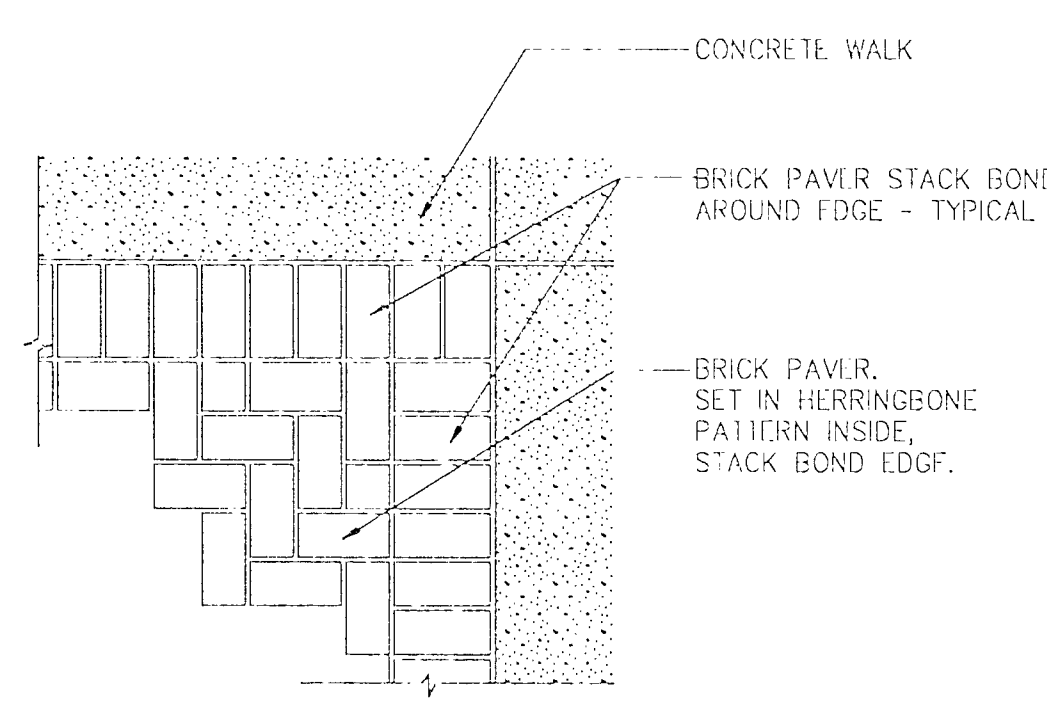

CONCRETE PAVERS - PLAN

NO SCALE


13
L104

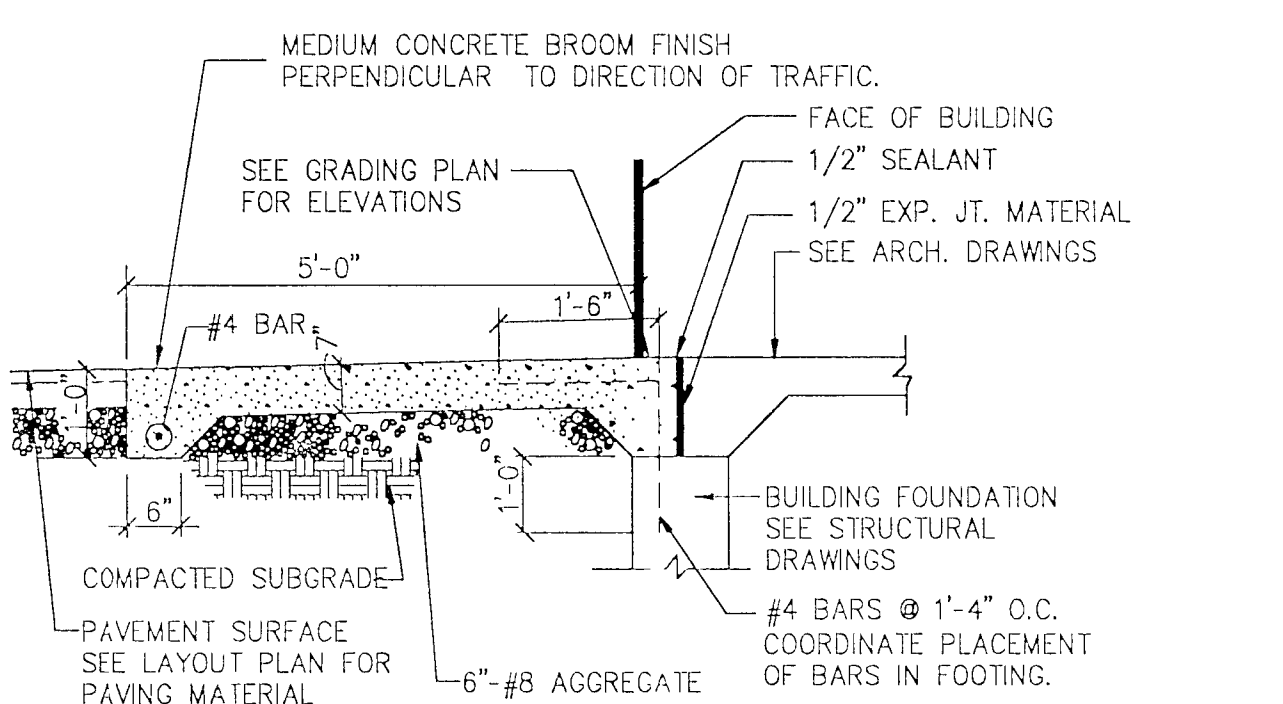

CONCRETE APRON SECTION

NO SCALE


6
L104

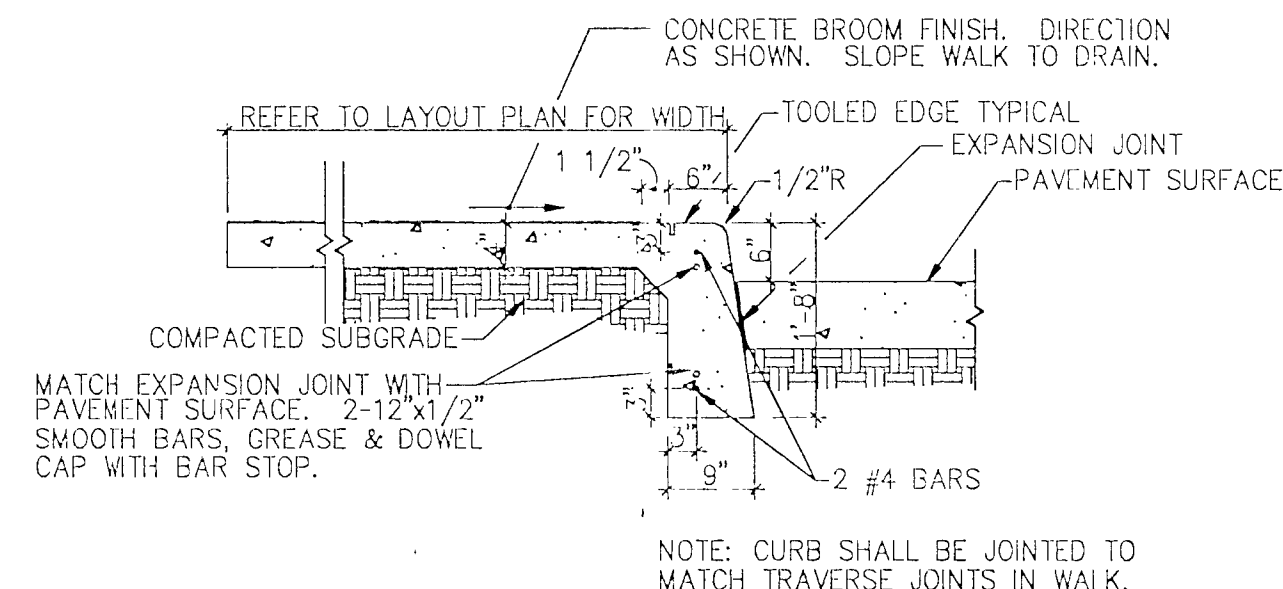

INTEGRAL CURB & WALK

NO SCALE


7
L104

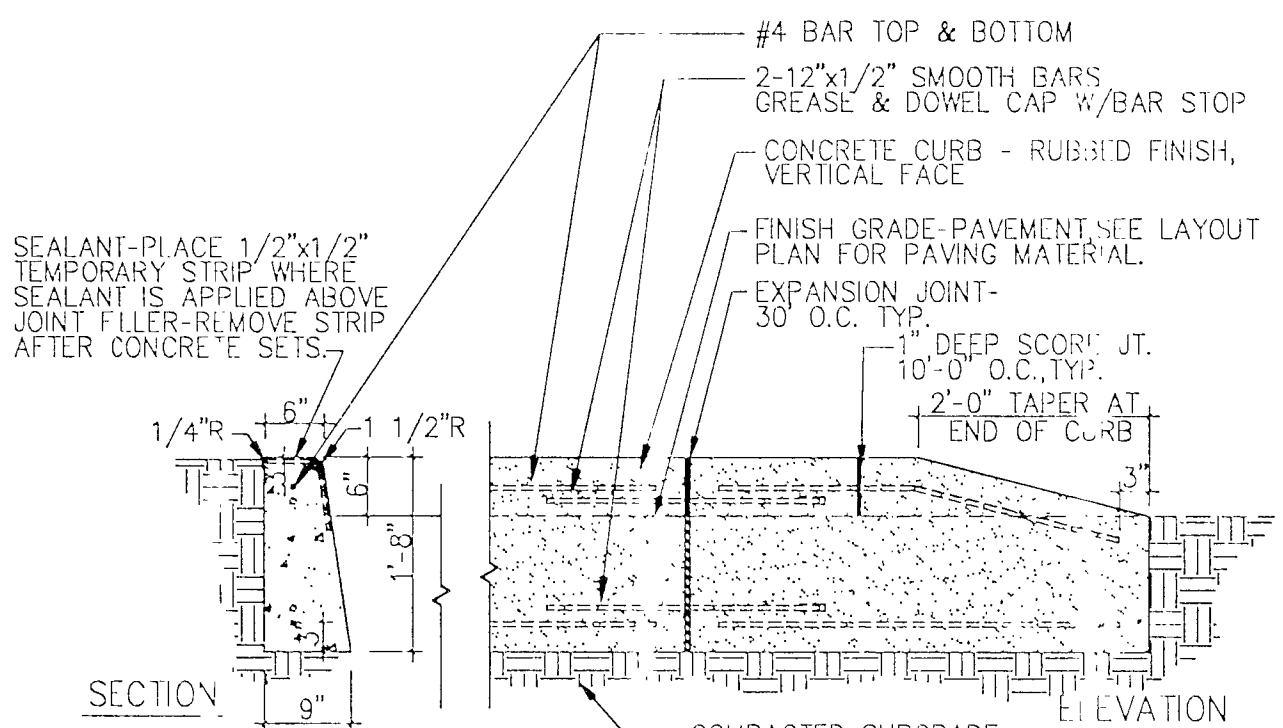

CONCRETE CURB

NO SCALE

8
L104

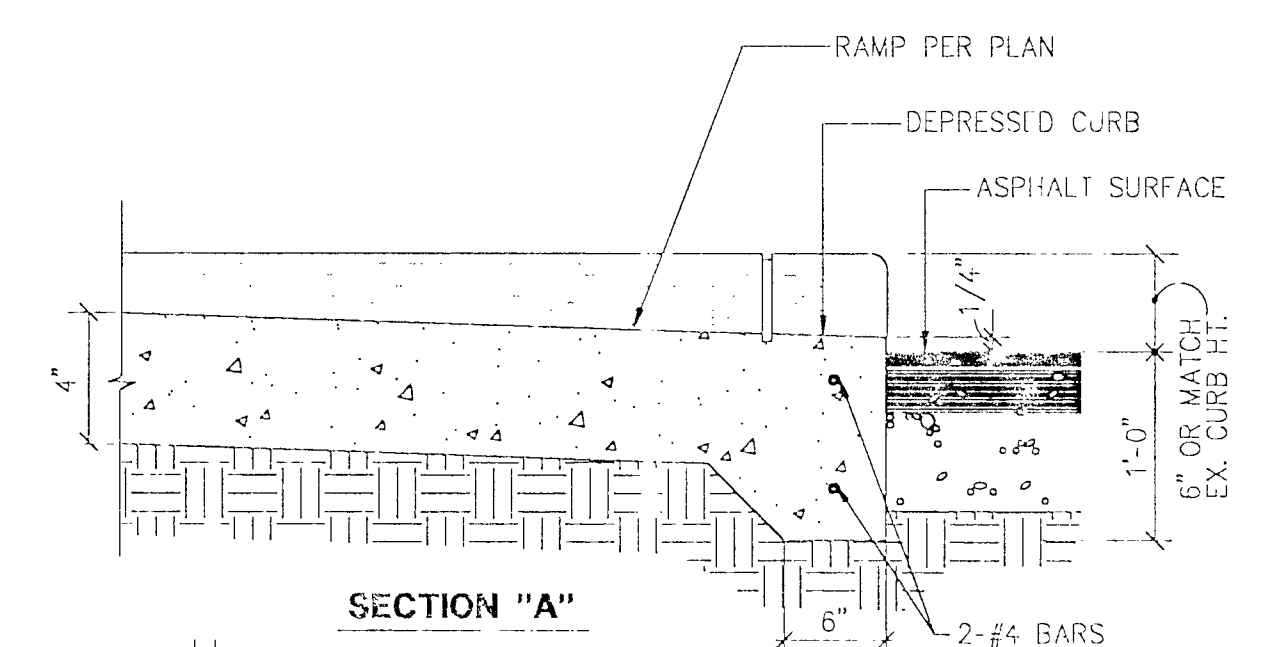

CONCRETE CURB


NO SCALE

9
L104

CONCRETE CURB

NO SCALE


9
L104

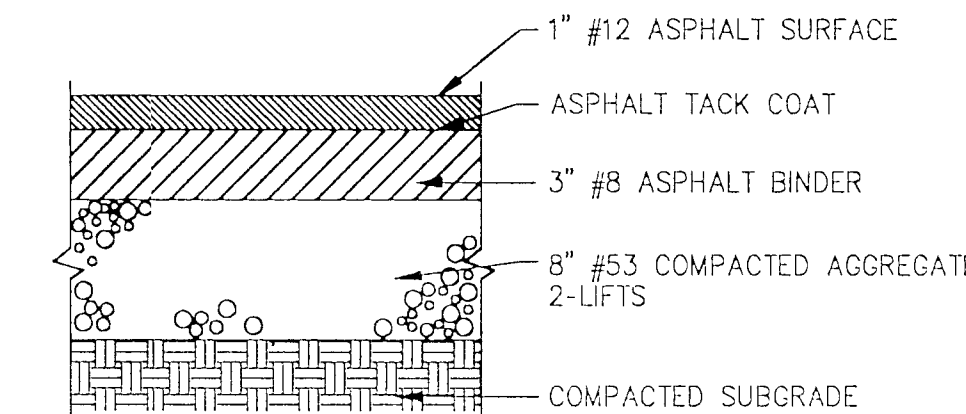

ASPHALT PAVING

NO SCALE


1
L104

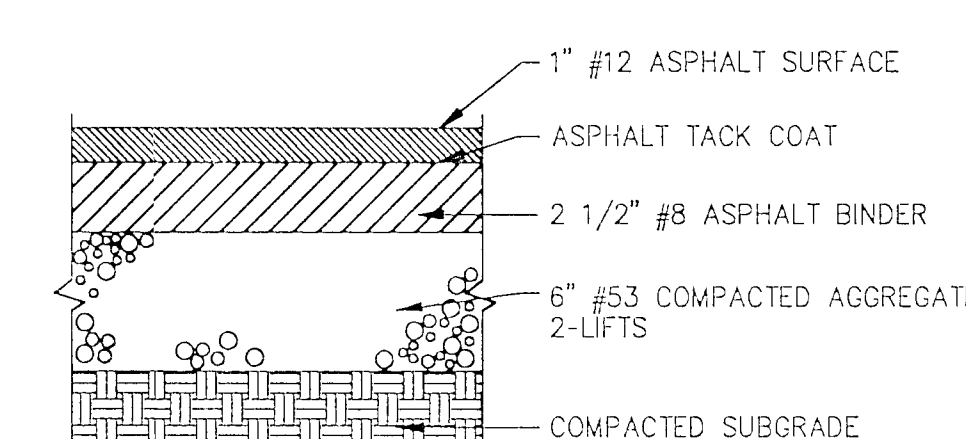

ASPHALT PAVING

NO SCALE


2
L104

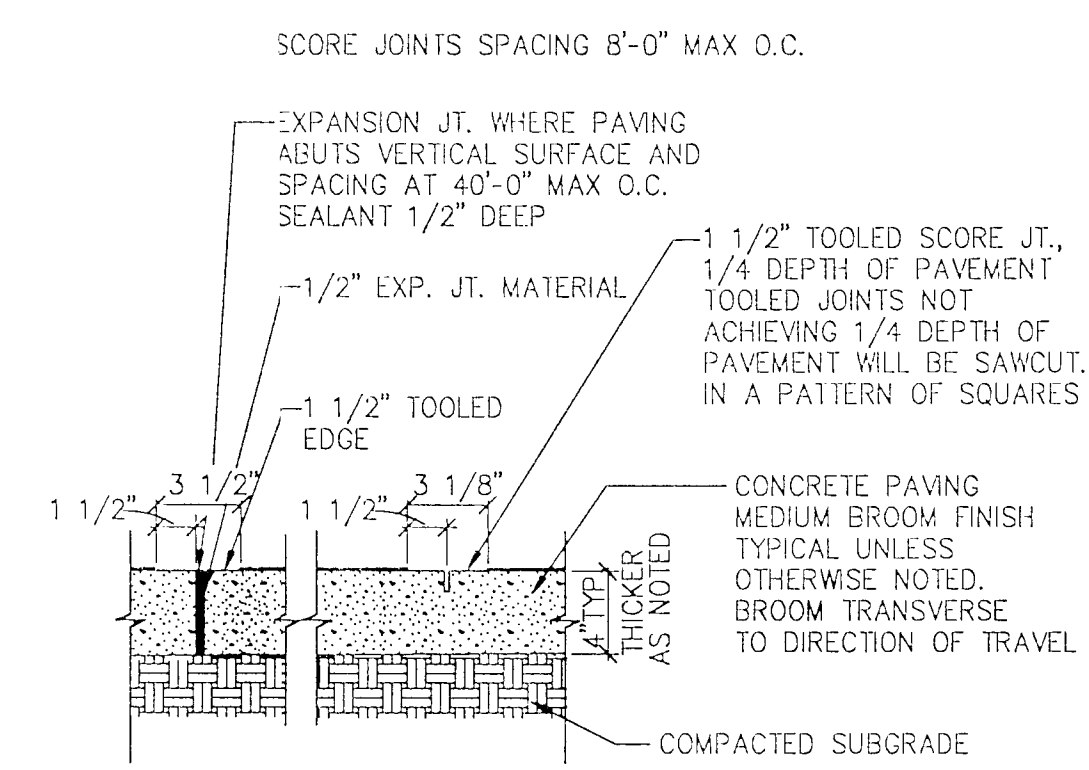

CONCRETE PAVING

NO SCALE


3
L104

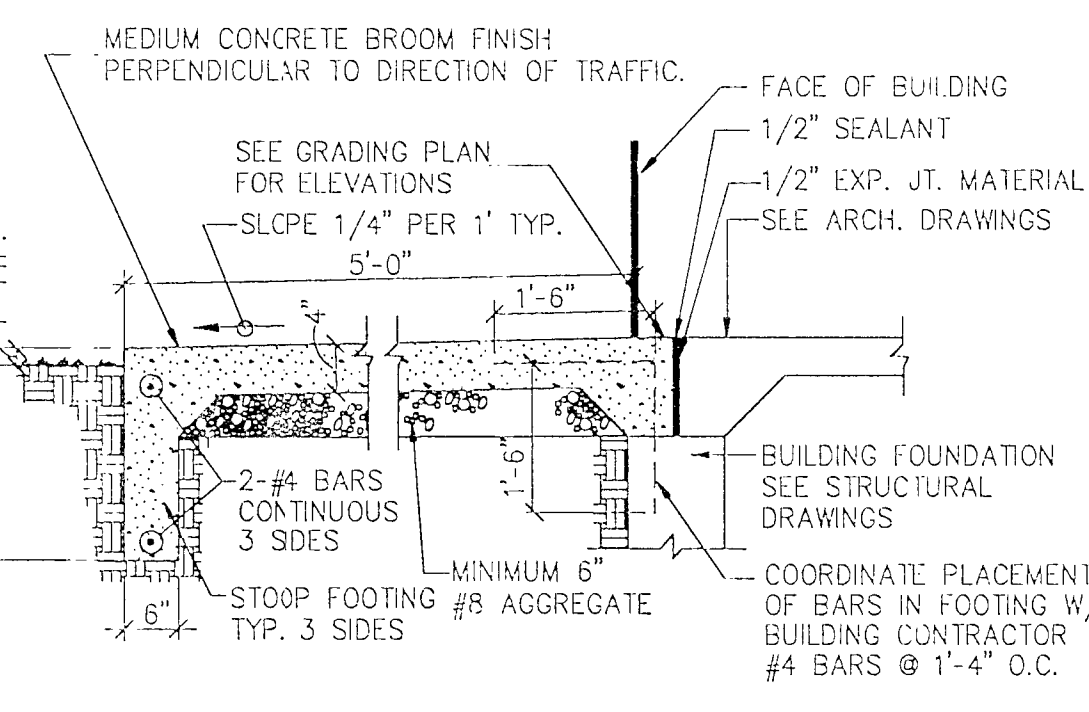

CONCRETE STOOP @ LAWN

NO SCALE


4
L104

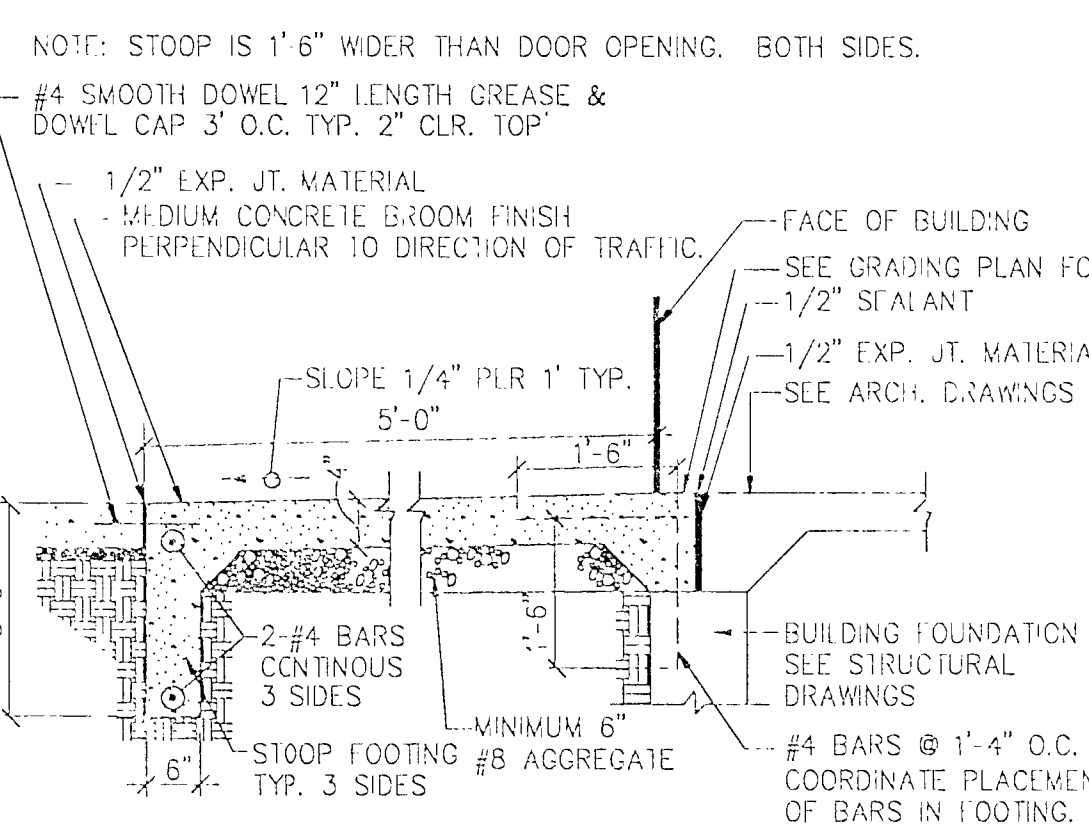

CONCRETE STOOP @ PAVING

NO SCALE

5
L104

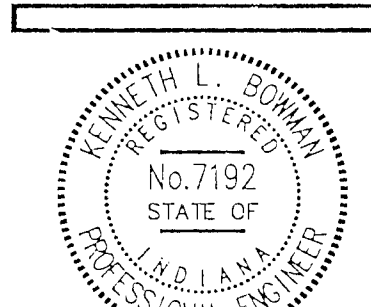

CERTIFIED

THE ODLE MCGUIRE & SHOOK CORPORATION
ARCHITECTURE • ENGINEERING • LANDSCAPE ARCHITECTURE • INTERIOR DESIGN
6765 NORTH STATE ROAD 37, POST OFFICE BOX 2149, BLOOMINGTON, INDIANA 47402, 812/676-2020
8275 ALLISON POINTE TRAIL, POST OFFICE BOX 50426, INDIANAPOLIS, INDIANA 46250, 317/642-0000

REVISIONS

© Copyright 1994 by THE ODLE MCGUIRE & SHOOK CORPORATION. Copyright includes construction work, including design, plans, drawings, and specifications. Architectural work is the result of the design, planning, and construction of spaces and elements in the design. Reproduction without written permission is prohibited.


MICHIGAN CITY SPORTS COMPLEX
AMES FIELD
MICHIGAN CITY, INDIANA

PROJECT NO. 93052
DATE 31 MAY 1994
drawn by: KJB, SMR
checked by: BWR

L104


SITE DETAILS

- NOTE:
1. TIE ALL FIELD SUBDRAINS TO NEW STORM DRAINAGE SYSTEM.
 2. END OF PLATER FLOW LINES TO BE CAPPED WITH GEOTEXTILE AND DUCT TAPE.
 3. FIELD IS AT LEVEL GRADE PER SPECIFICATIONS.
 4. ROGER BOSSARD SYSTEM FIELD DRAINAGE PLAN AND IRRIGATION SYSTEM DESIGN FURNISHED BY MUELLERMIST IRRIGATION CO.

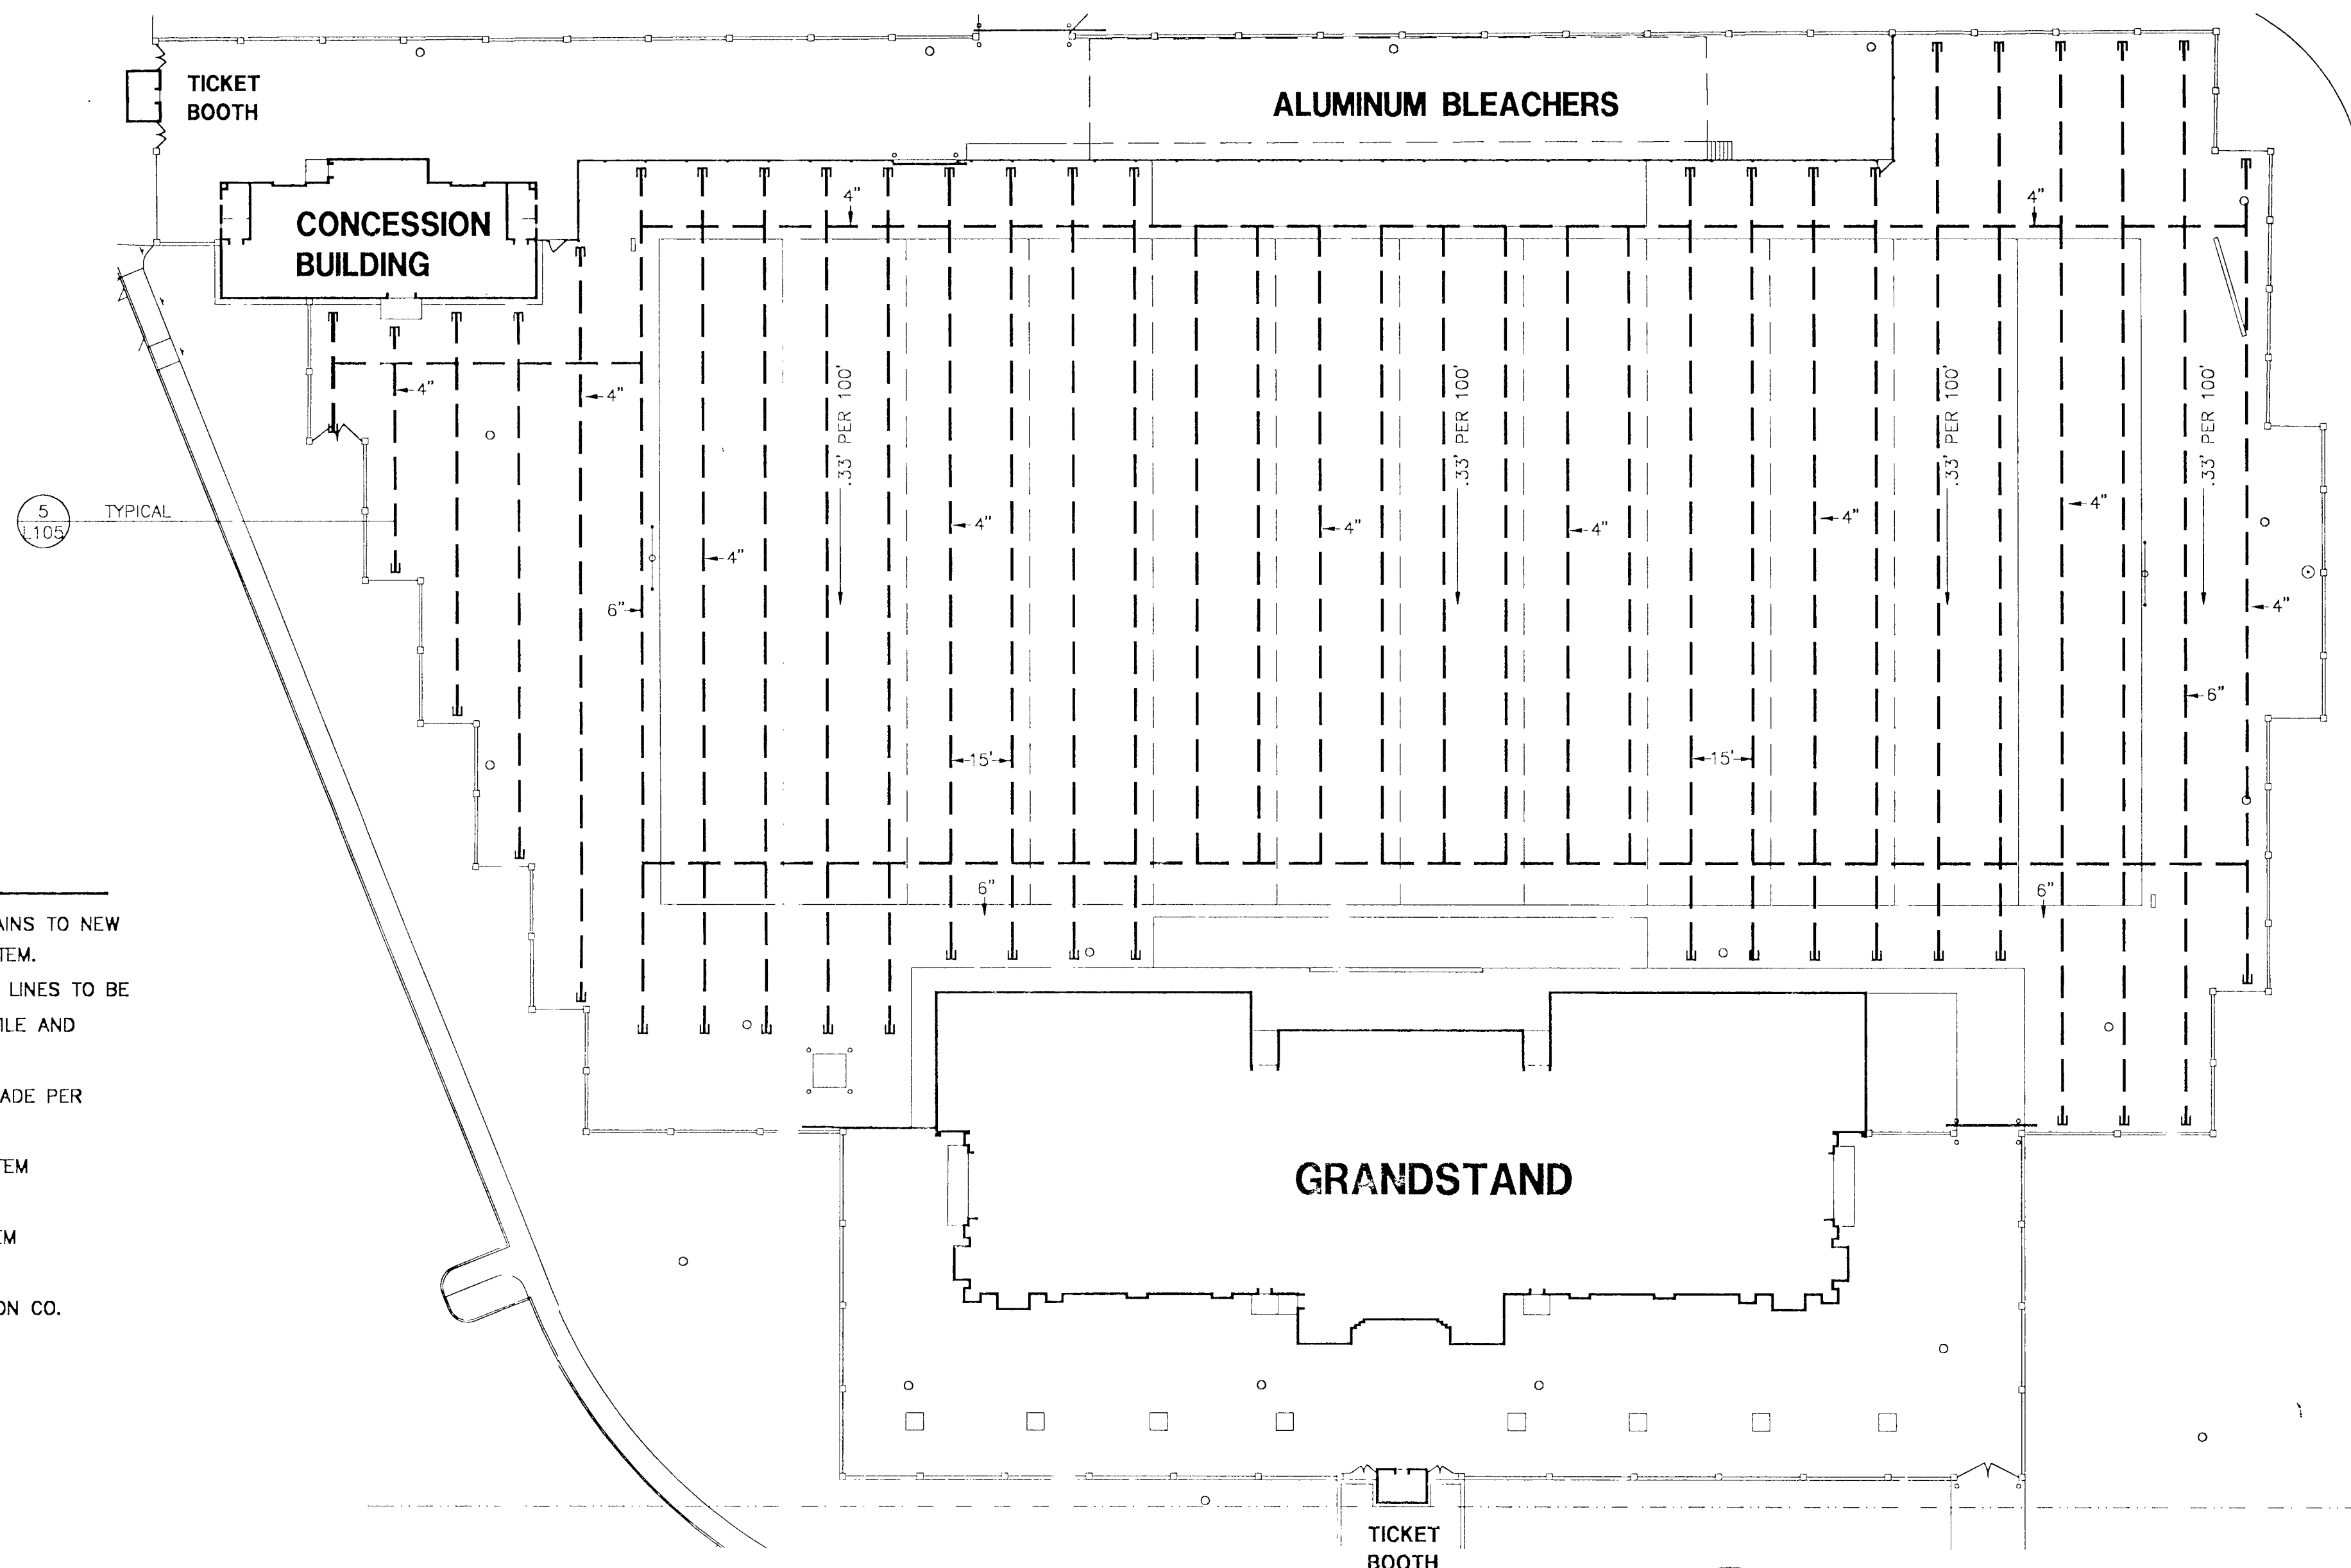

FIELD DRAINAGE ENLARGEMENT PLAN
SCALE: 1"=30'-0"


10
L105

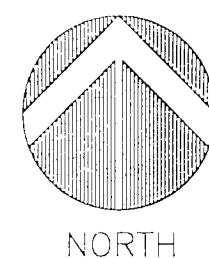

SPRINKLER HEAD LEGEND			
KEY	NAME	MODEL #	QTY
△	HUNTER ROTARY	I40 35V	29
△	HUNTER ROTARY	I40 ADJ	21
▲	HUNTER ROTARY	PQ77C	1
▲	HUNTER ROTARY	PQ77C	19
TOTAL HEADS			70



NOTE:

ROGER BOSSARD SYSTEM
FIELD DRAINAGE PLAN
AND IRRIGATION SYSTEM
DESIGN FURNISHED BY
MUELLERMIST IRRIGATION CO.

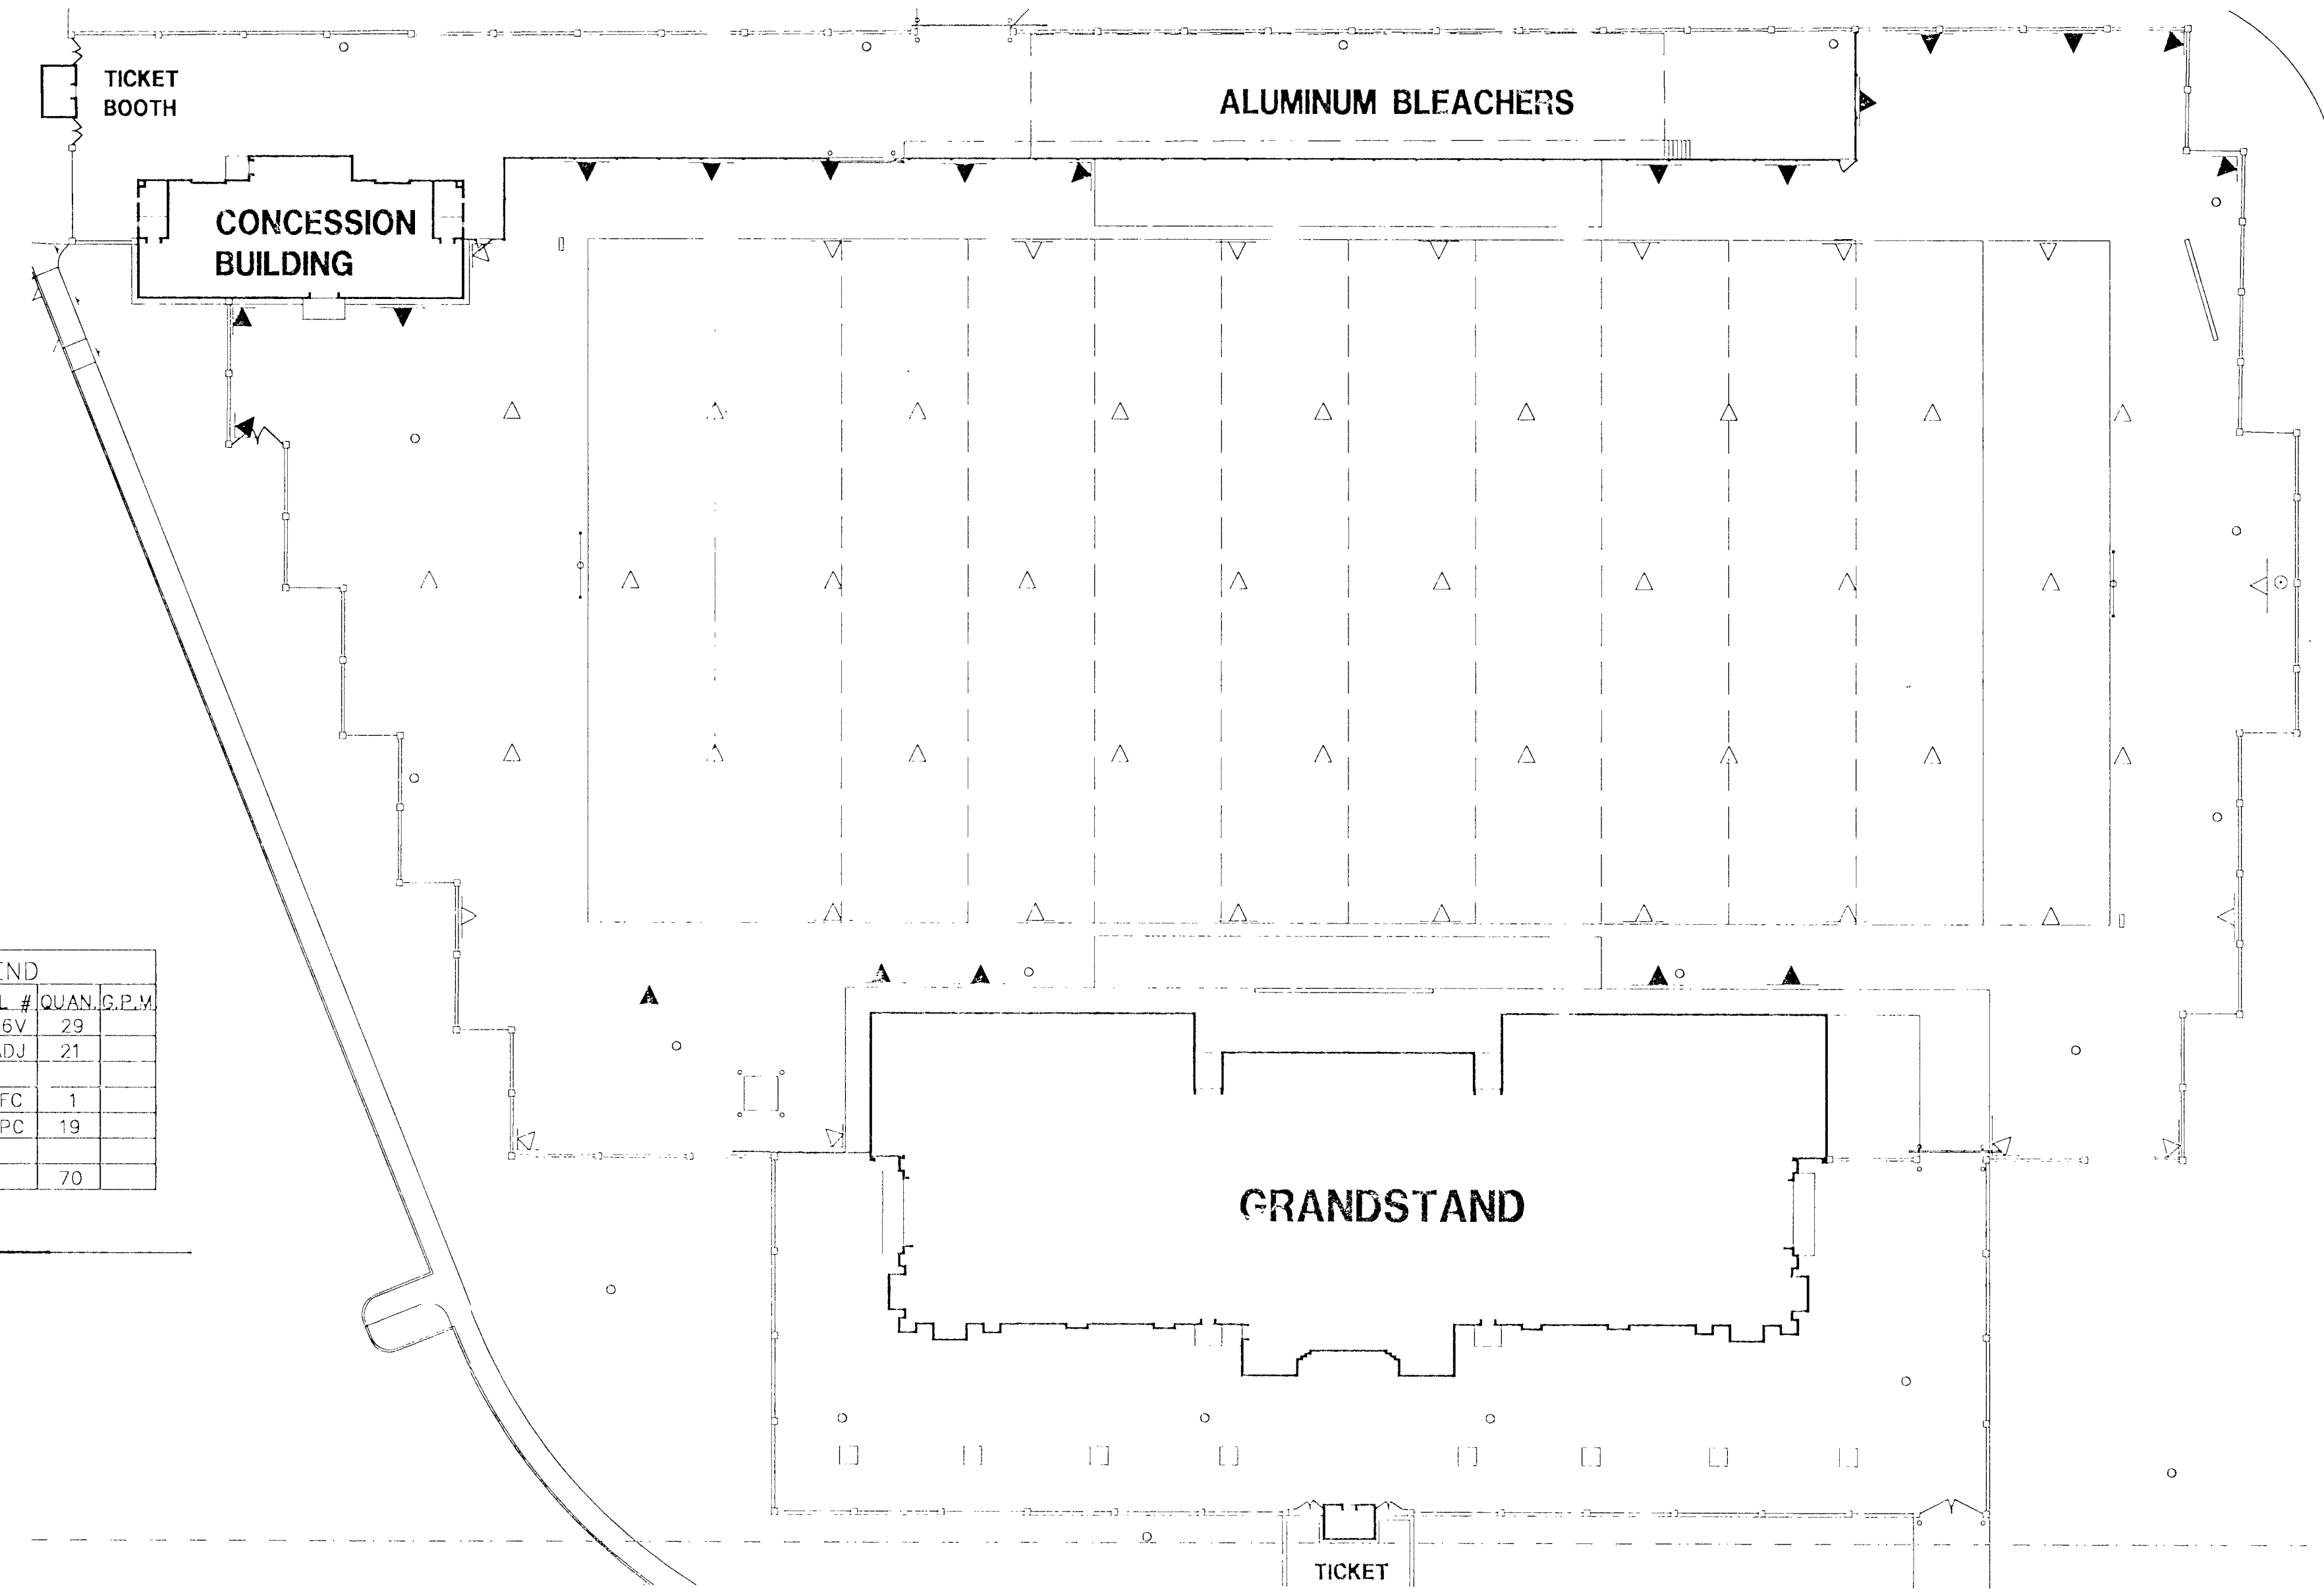


FIELD IRRIGATION ENLARGEMENT PLAN
SCALE: 1"=30'-0"

11
L105

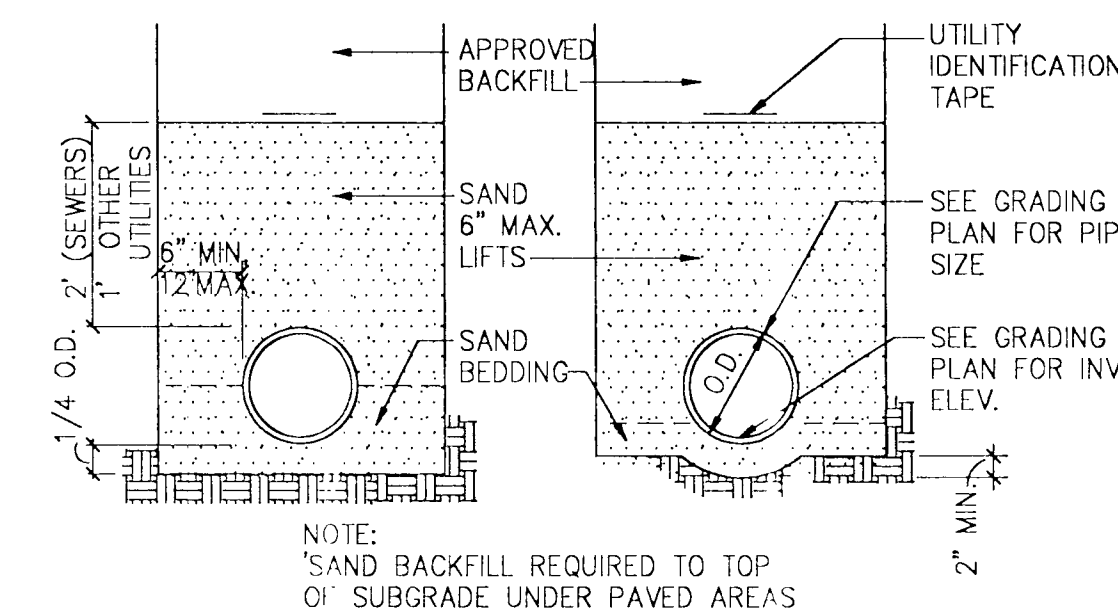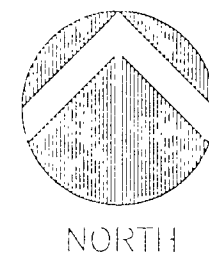


PIPE BEDDING & BACKFILL
NO SCALE

6
L105

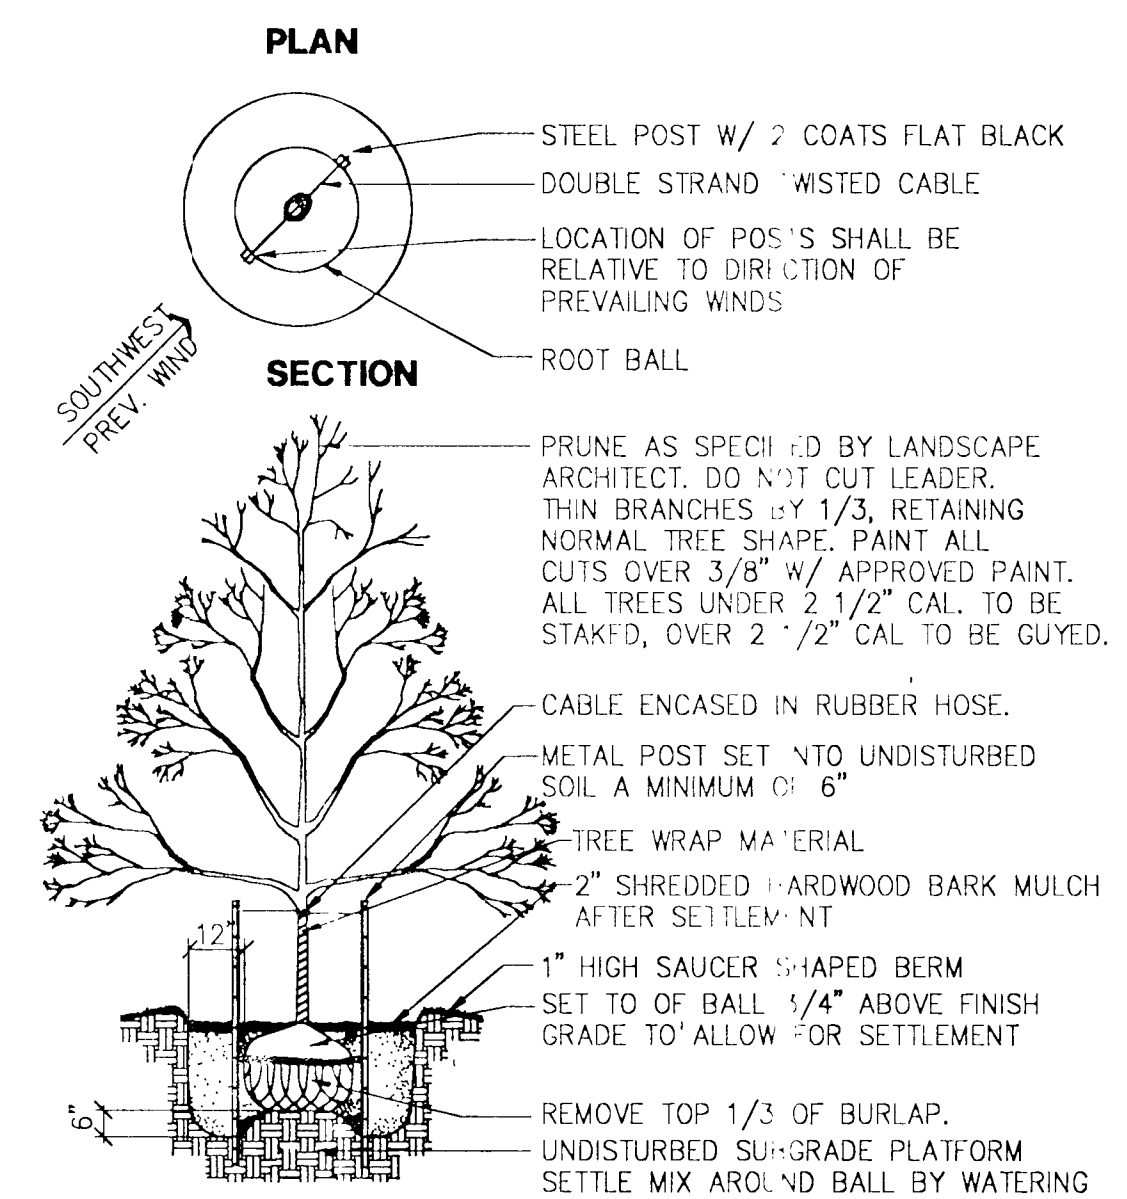


TREE STAKING DETAIL
NO SCALE

7
L105

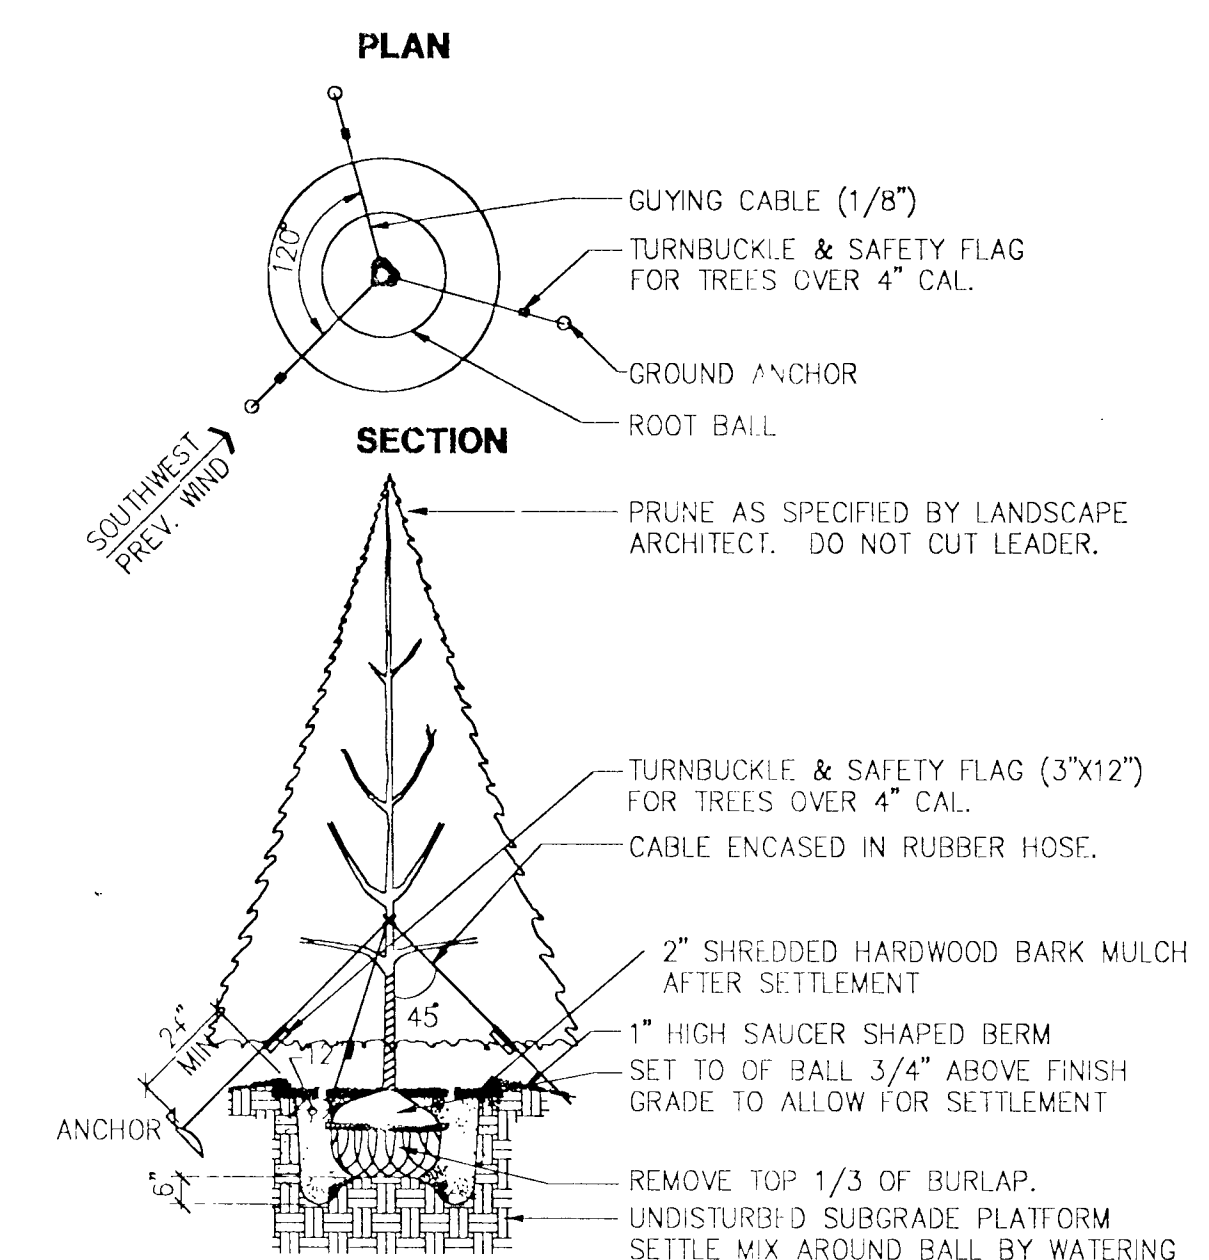


EVERGREEN TREE DETAIL
NO SCALE

8
L105

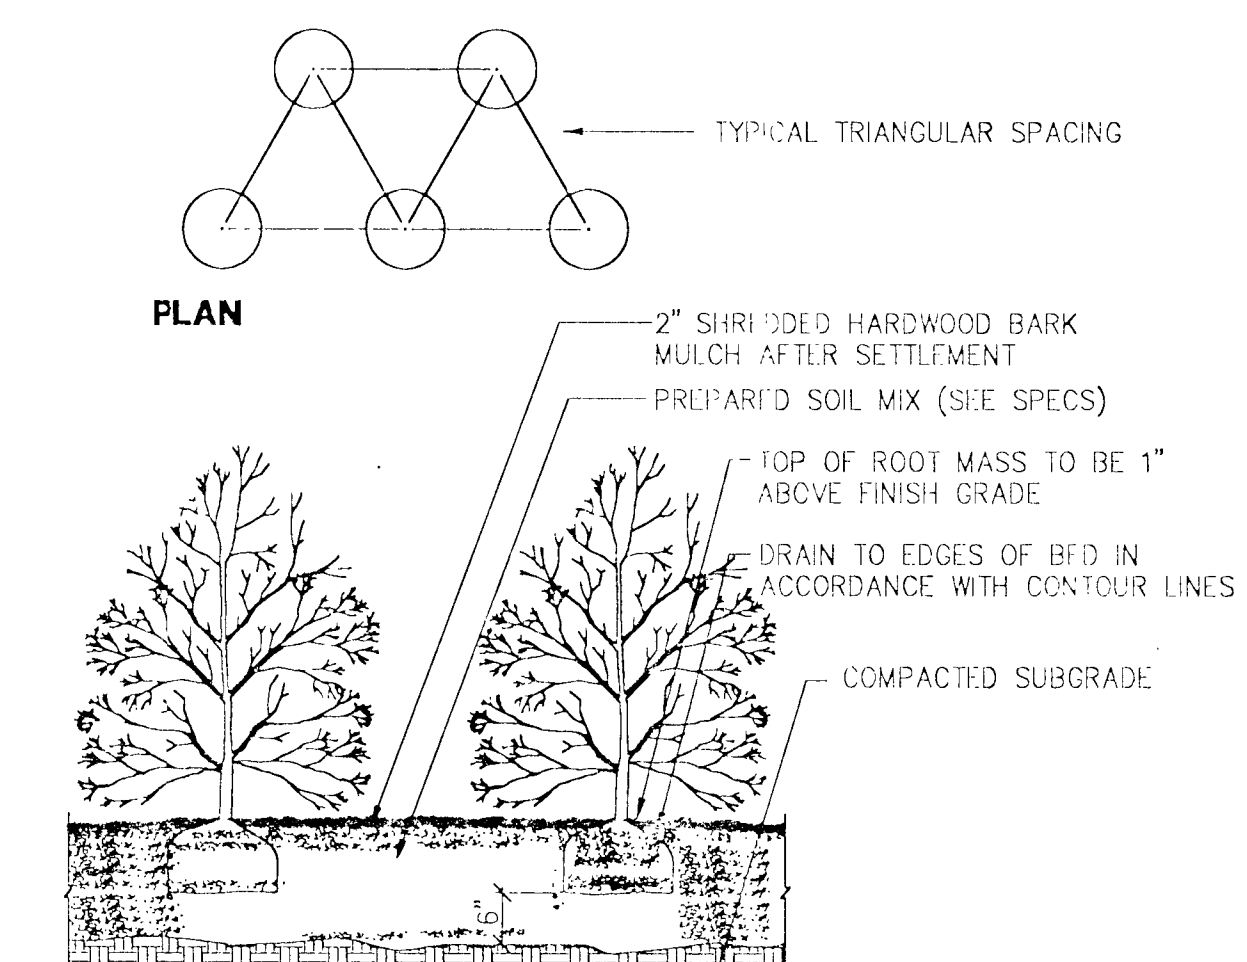


SHRUB PLANTING DETAIL
NO SCALE

9
L105

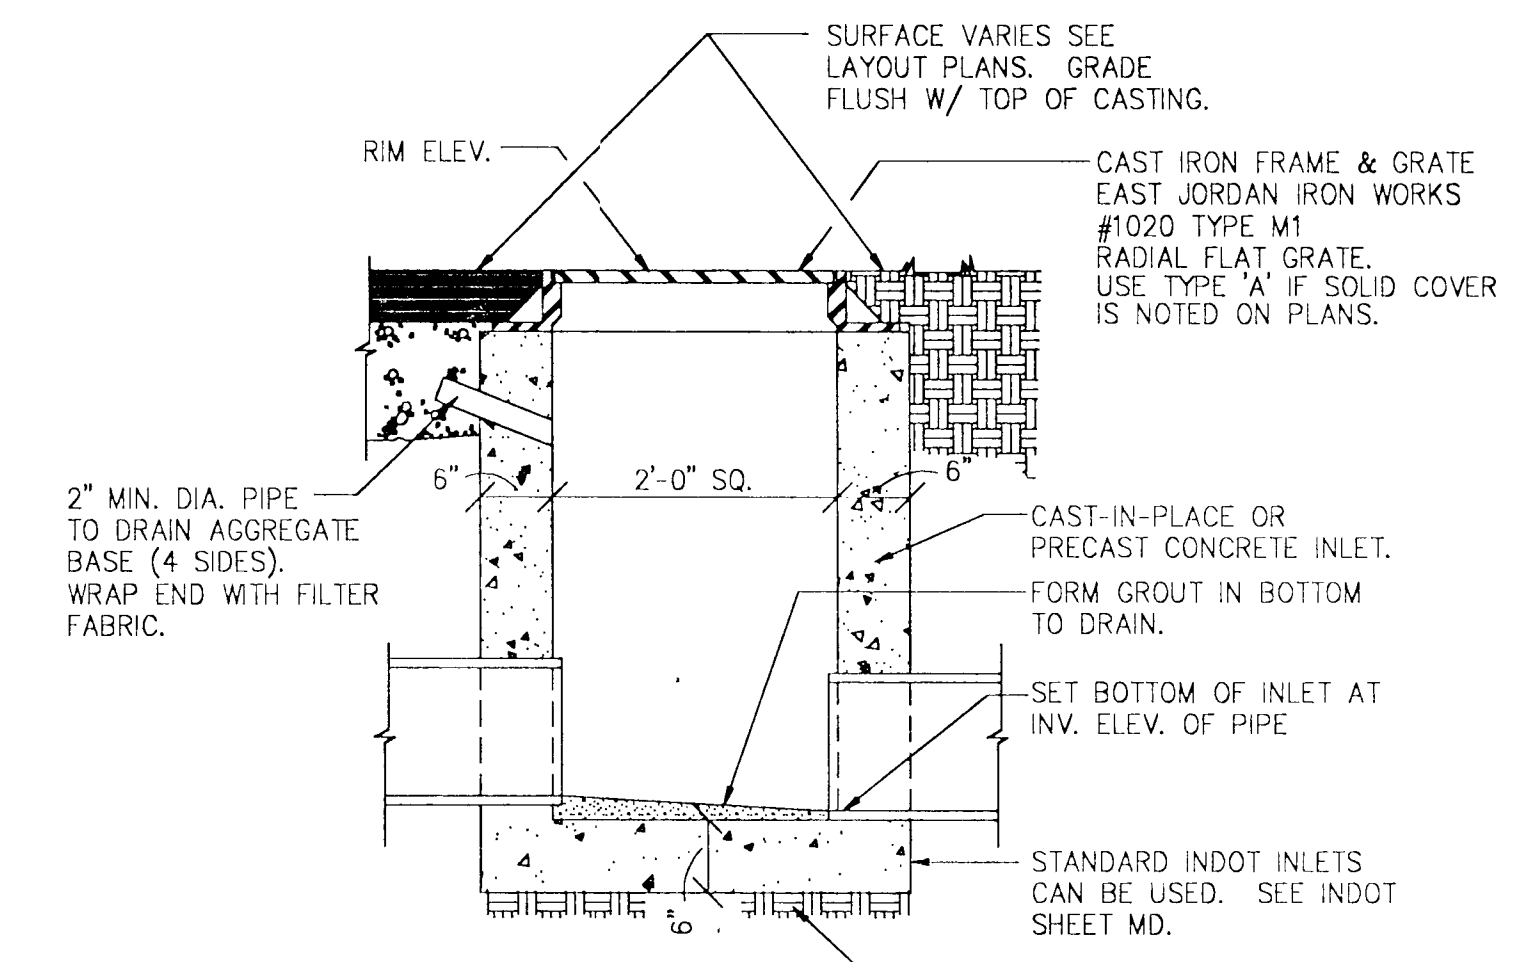


PAVING AND YARD INLET
NO SCALE

1
L105

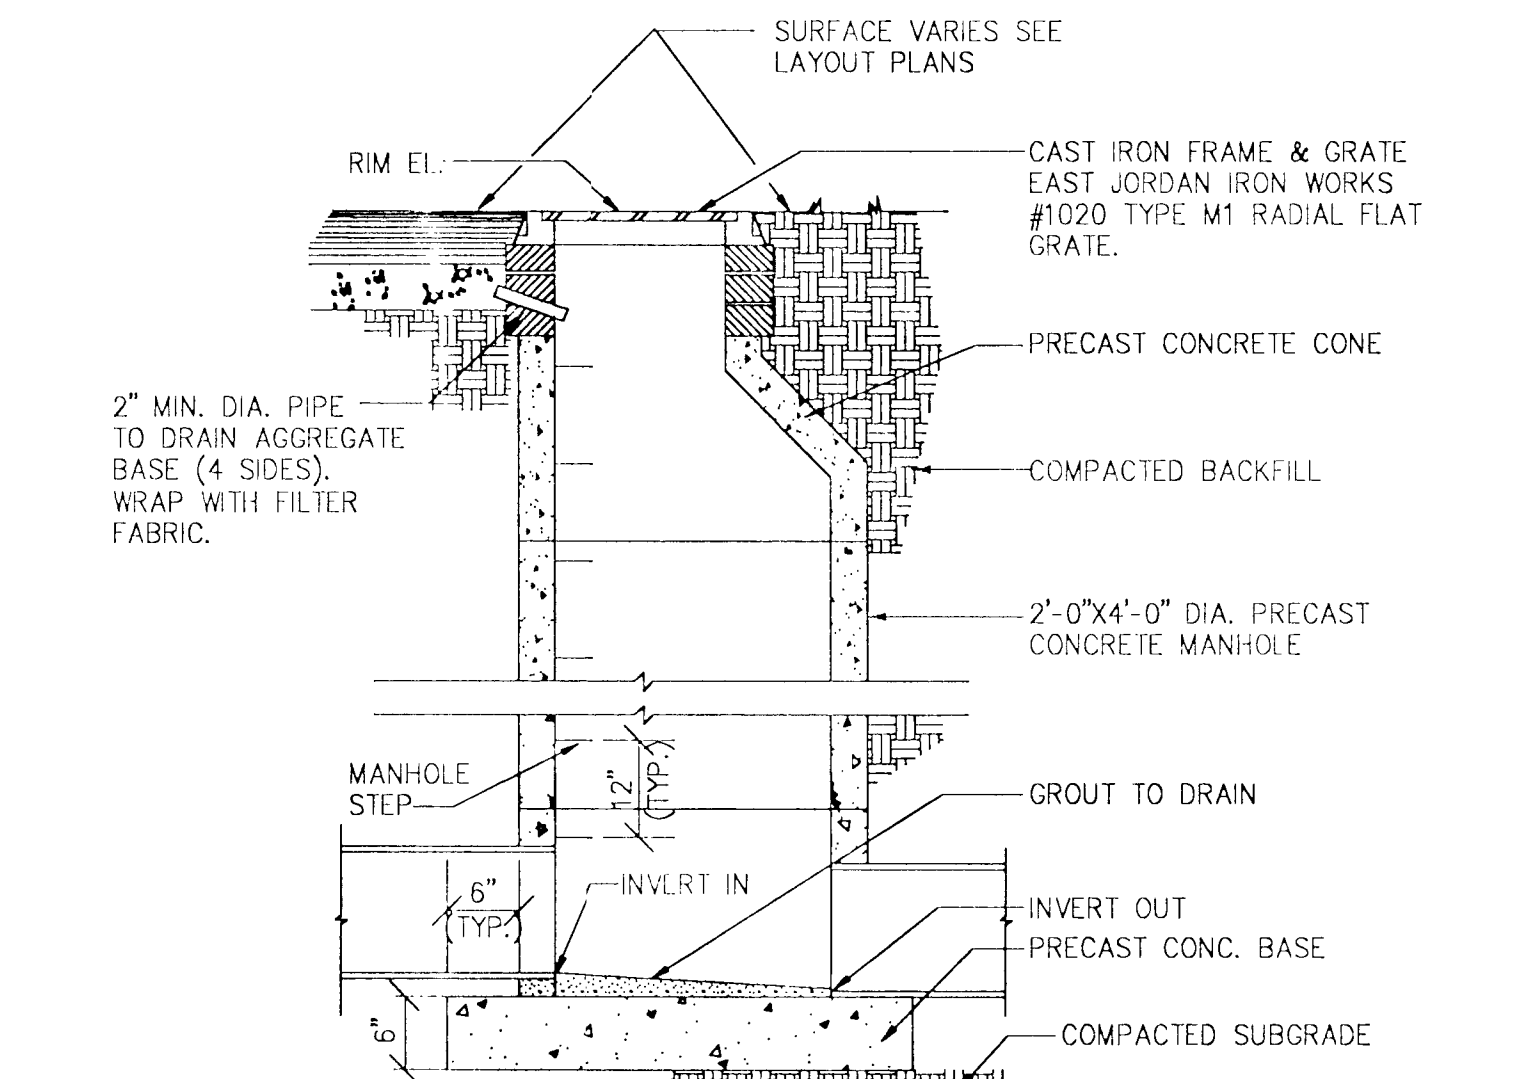


MANHOLE DETAIL
NO SCALE

2
L105

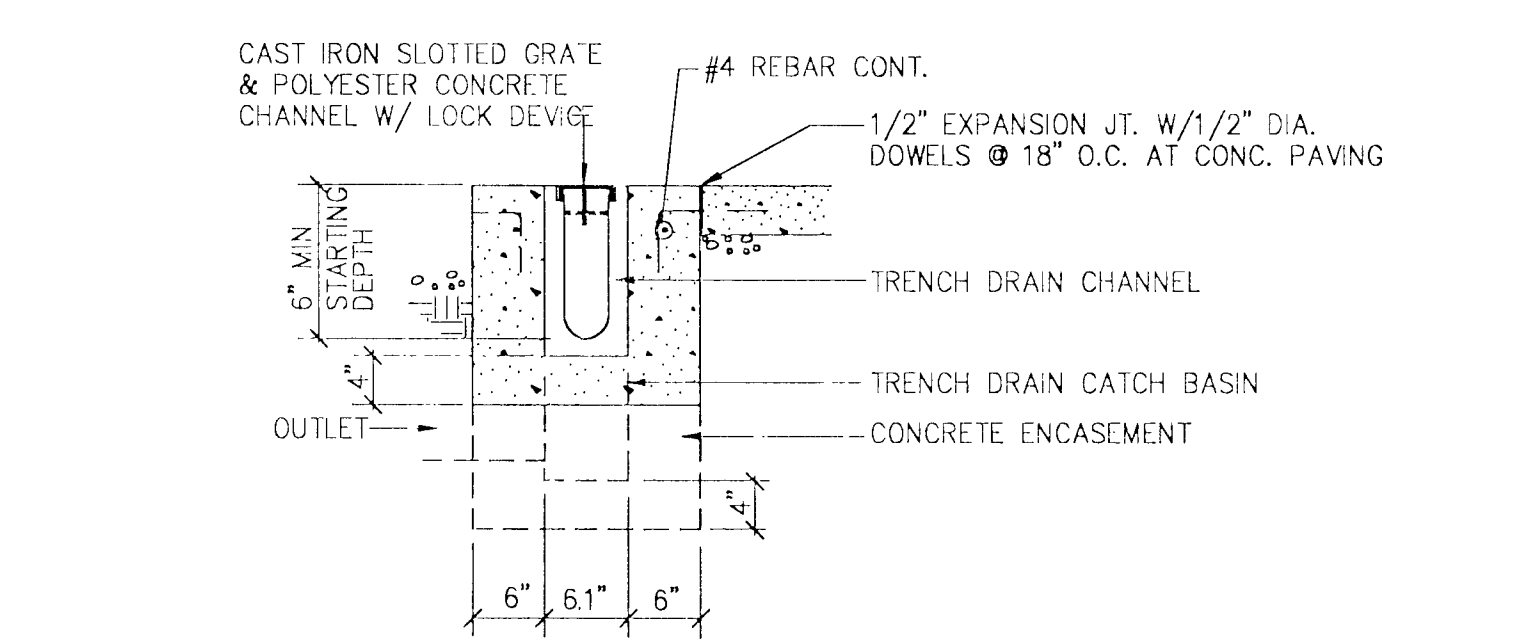


PRECAST TRENCH DRAIN DETAIL
NO SCALE

3
L105

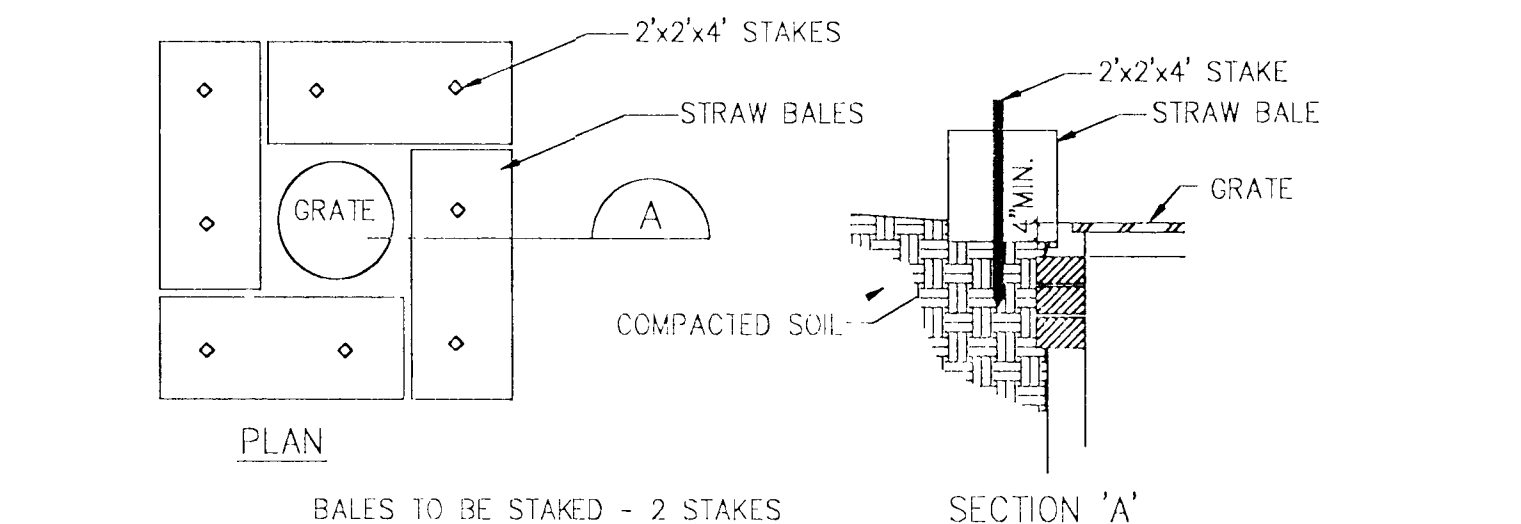

SEDIMENT FILTER DETAIL
NO SCALE

4
L105

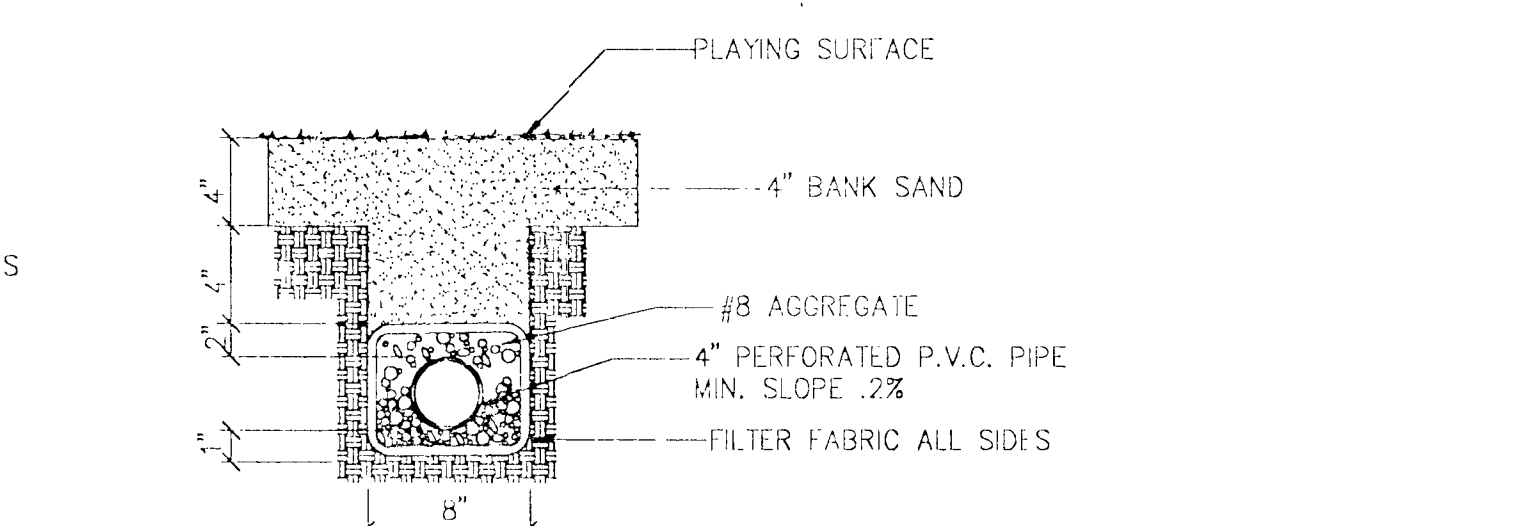

SUBSOIL DRAIN
NO SCALE

5
L105



CERTIFIED

THE ODLE MCGUIRE & SHOOK CORPORATION
ARCHITECTURE • ENGINEERING • LANDSCAPE ARCHITECTURE • INTERIOR DESIGN
8755 NORTH STATE ROAD 37, SUITE 200, OFFICE BOX 2148, BLOOMINGTON, INDIANA 47403, 812/875-2000
8275 ALLESTON DRIVE, SUITE 100, POST OFFICE BOX 54428, INDIANAPOLIS, INDIANA 46250, 317/842-0000


REVISIONS

Copyright 1994 by THE ODLE MCGUIRE & SHOOK CORPORATION. Copyright includes architectural work, building design, plans or drawings, and specifications. Architectural work is the result of the design and engineering team and is the property of THE ODLE MCGUIRE & SHOOK CORPORATION. No part of this design, reproduction, or distribution without written permission is prohibited.

MICHIGAN CITY SPORTS COMPLEX
AMES FIELD
MICHIGAN CITY, INDIANA

PROJECT NO. 93052
DATE: 31 MAY 1994
drawn by: SMR/KJB
checked by: BWR

L105
SITE DETAILS

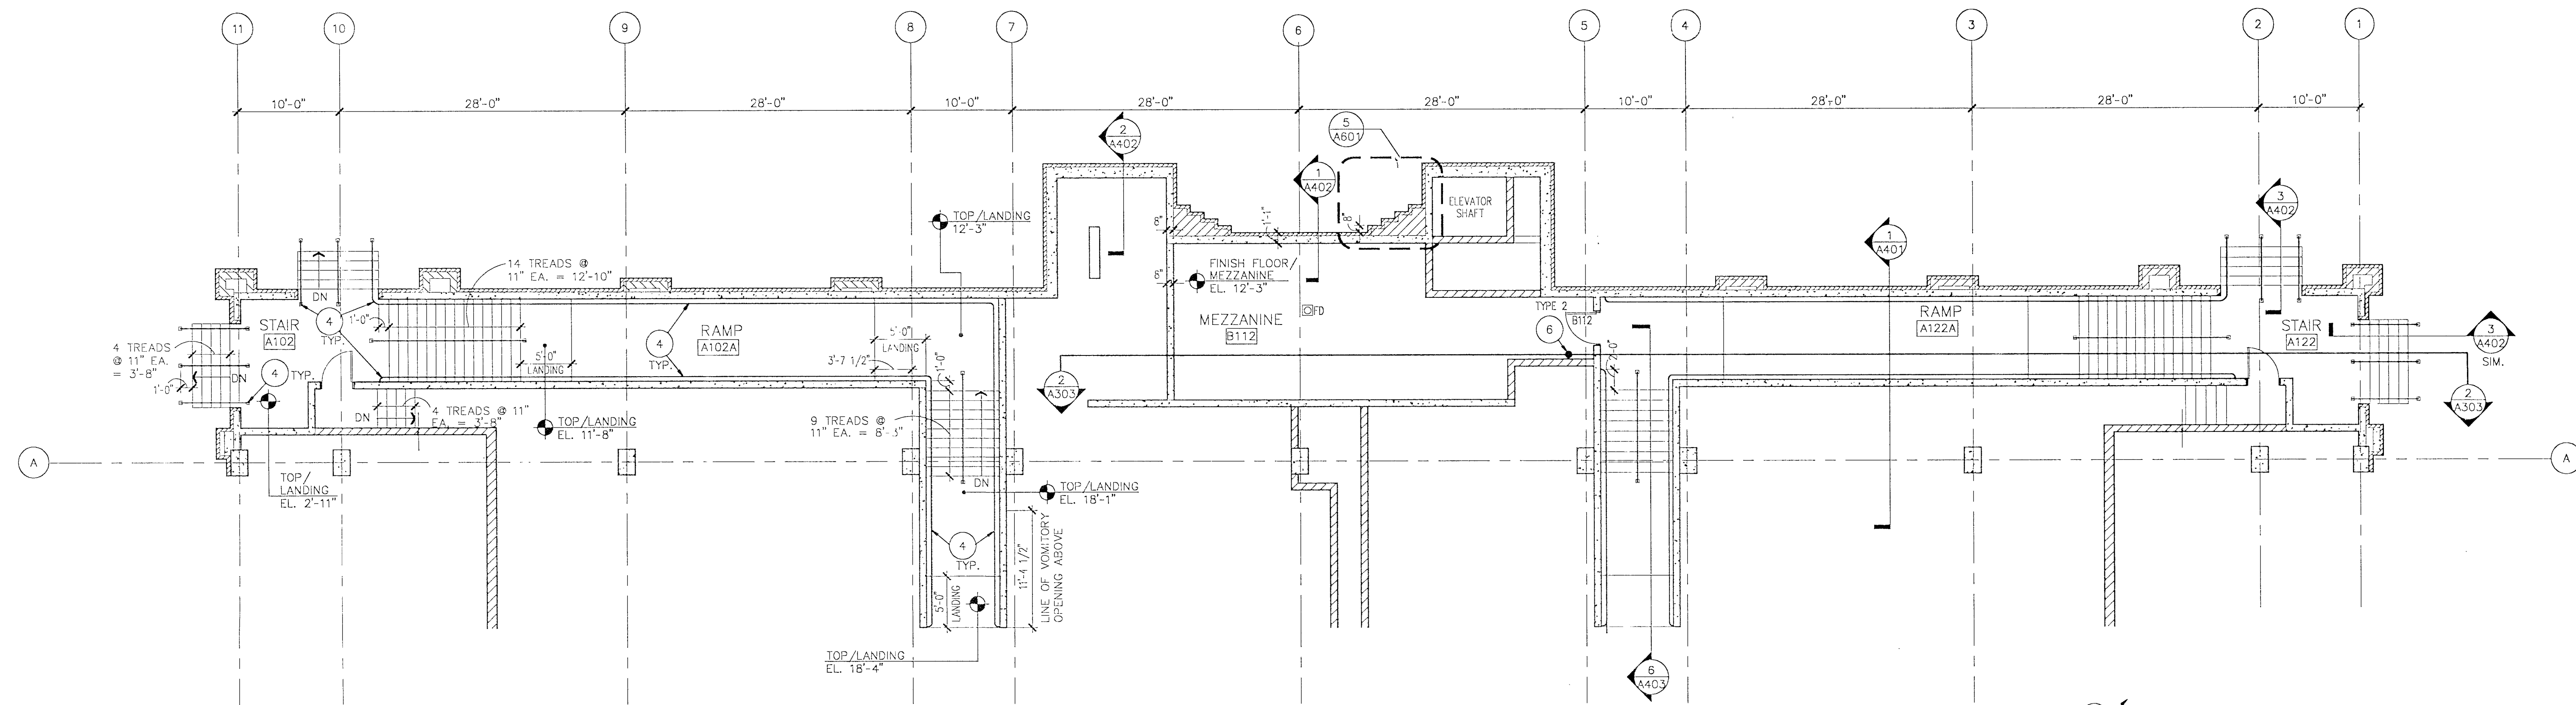

FOOTBALL STADIUM INTERIOR RAMP PLAN

SCALE: 1/8" = 1'-0"




NUMBERED PLAN NOTES

1. 12'-0" ALUMINUM FLAGPOLE R/F: 10/A601.
2. 18'-0" ALUMINUM FLAGPOLE R/F: 10/A601.
3. ALUMINUM GUARDRAIL, REF: SHEET A602.
4. ALUMINUM HANDRAIL, REF: 5/A603.
5. FIRE EXTINGUISHER AND CABINET, REF: 12/A601.
6. FIRE EXTINGUISHER AND HOLDER.
7. NORMAL WEIGHT CMU, GROUT WALL FULL HEIGHT.
8. PLASTIC LAMINATE TOP, REF: 9/A603.
9. ARCHITECTURAL PRECAST PANEL, FINISH TO MATCH RISERS.
10. INDICATES A PRECAST CONCRETE OPENING AT HEAD HOT.
11. 7'-5" A.F.F. THRESHOLD OR SILL TO BE 0'-6" A.F.F.
12. NOT USED.
13. SEE DETAIL 10/A603 FOR PERIMETER JOINTS AT WALLS WHICH PENETRATE THE FLOOR SLAB.
14. METAL LOCKERS REF: 13/A601.
15. METAL SIGNAGE SEE SHEET A604.


GENERAL PLAN NOTES

1. ALL WALL THICKNESSES ARE NOMINAL UNLESS INDICATED OTHERWISE.
2. ALL PRECAST STAIR TREADS TO HAVE SWIRL FINISH TO MATCH RISERS UNLESS INDICATED OTHERWISE.
3. WHERE NOT DIMENSIONED, LOCATE HINGE SIDE OF DOOR FRAME 4" FROM WALL PERPENDICULAR TO DOOR FRAME.
4. ALL JOINTS ARE TO BE SEALED TO MAKE THIS BUILDING WATER TIGHT (WHETHER SHOWN OR NOT).
5. REFERENCE STRUCTURAL DRAWINGS FOR CONTROL JOINT LOCATIONS.
6. ALL EXPOSED CORNERS OF CMU SHALL BE BULLNOSED.
7. PROVIDE BOND BEAM OR STEEL LINTEL OVER ALL OPENINGS IN MASONRY WALLS. SEE ARCHITECTURAL DOOR AND FRAME SCHEDULE FOR LINTEL SCHEDULE. SEE MECHANICAL DRAWINGS FOR SIZE AND LOCATION OF MECHANICAL OPENINGS.
8. FOR HEIGHT OF WALLS AND/OR PARTITIONS ABOVE FINISHED CEILING, AND WALLS WHICH EXTEND TO THE UNDERSIDE OF RISERS, REF: SHEET A204.
9. TYPICAL EXTERIOR WALLS ARE 8" PRECAST CONCRETE WALL PANELS W/ 4" FACE BRICK, ACTUAL WALL THICKNESS OF 1'-1". NO INSULATION NEED BE PROVIDED IN WALL SYSTEM.
10. WHERE CONCRETE WALL PANEL IS EXPOSED TO VIEW, SHOW STEEL FORM FINISH. WHERE BOTH SIDES ARE EXPOSED TO VIEW PROVIDE TROWEL FINISH ON SECOND SIDE.

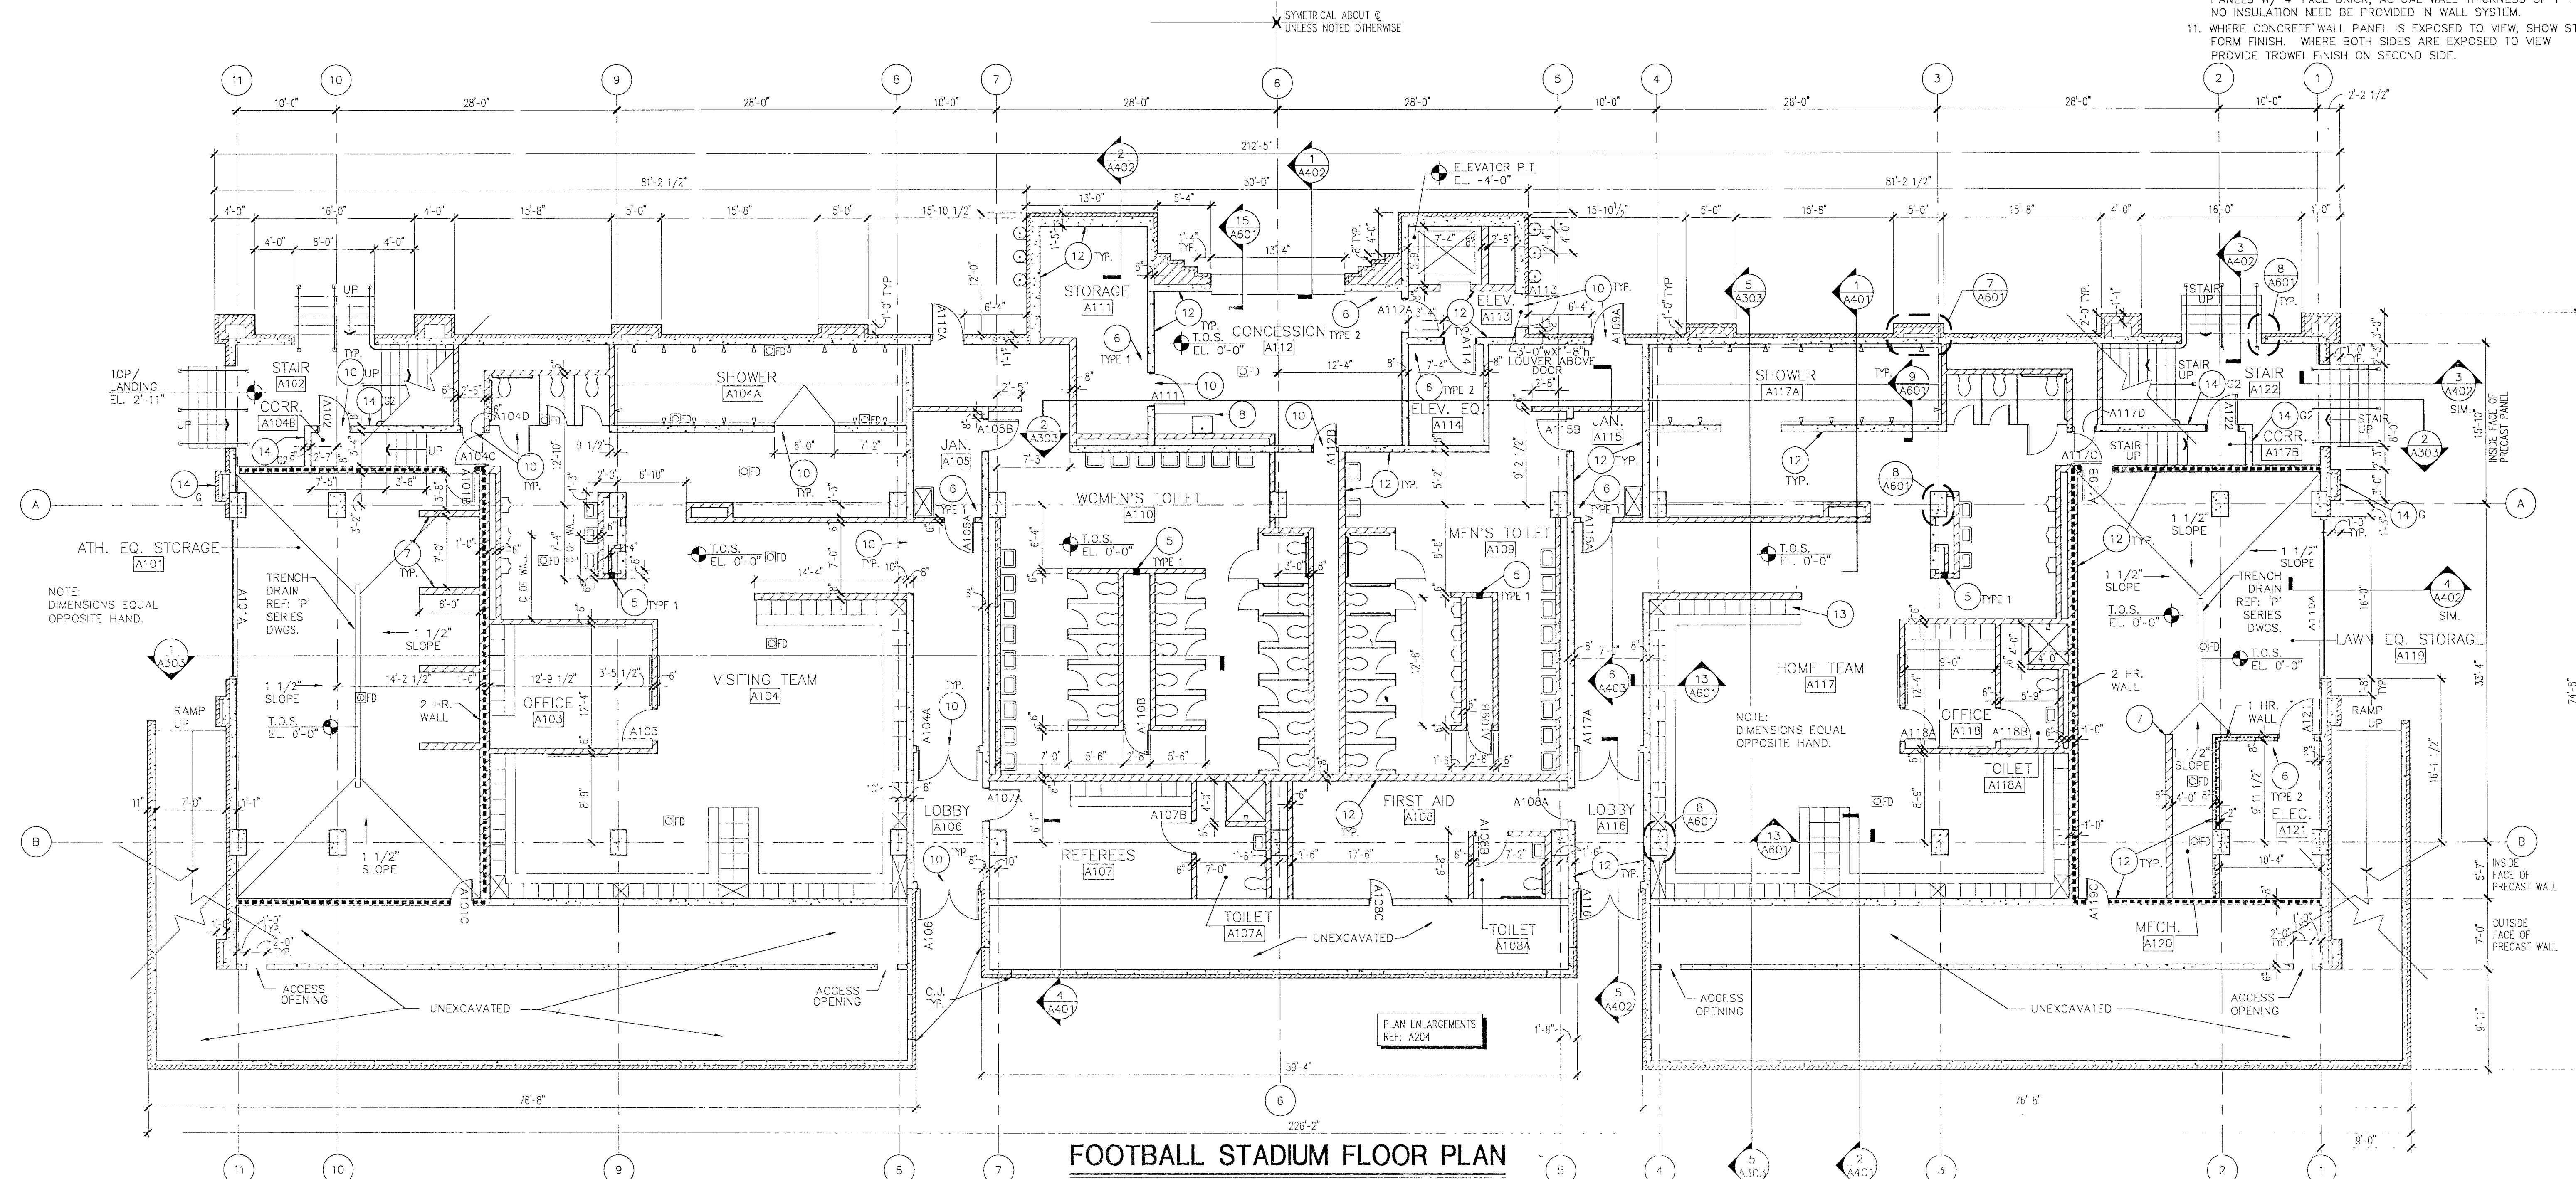

FOOTBALL STADIUM FLOOR PLAN

SCALE: 1/8" = 1'-0"

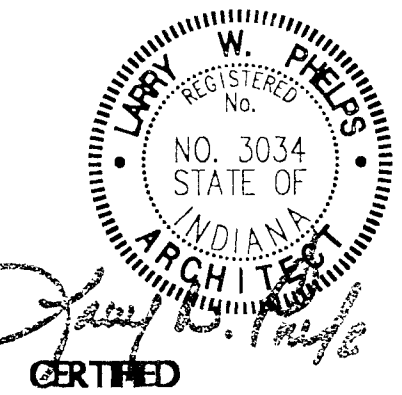

THE ODLE MCGURE & SHOOK CORPORATION
ARCHITECTURE • ENGINEERING • LANDSCAPE ARCHITECTURE • INTERIOR DESIGN
6765 NORTH STATE ROAD 37, POST OFFICE BOX 7148, BLOOMINGTON, INDIANA 47402, 817/876-2020
8275 ALISON POINTE TRAIL, POST OFFICE BOX 30426, INDIANAPOLIS, INDIANA 46231, 317/842-0080


REVISIONS

© Copyright 1984 by THE ODLE MCGURE & SHOOK CORPORATION. Copyright includes architectural work, building design, plans or drawings, and specifications. Architectural work is the overall form as well as the arrangement and composition of space and materials in the design. Reproduction without written permission is prohibited.

MICHIGAN CITY SPORTS COMPLEX
AMES FIELD
MICHIGAN CITY, INDIANA


PROJECT NO. 93052
DATE: MAY 31, 1994
drawn by: MFM
checked by: GKJ

A201
FLOOR PLANS
FOOTBALL GRANDSTAND

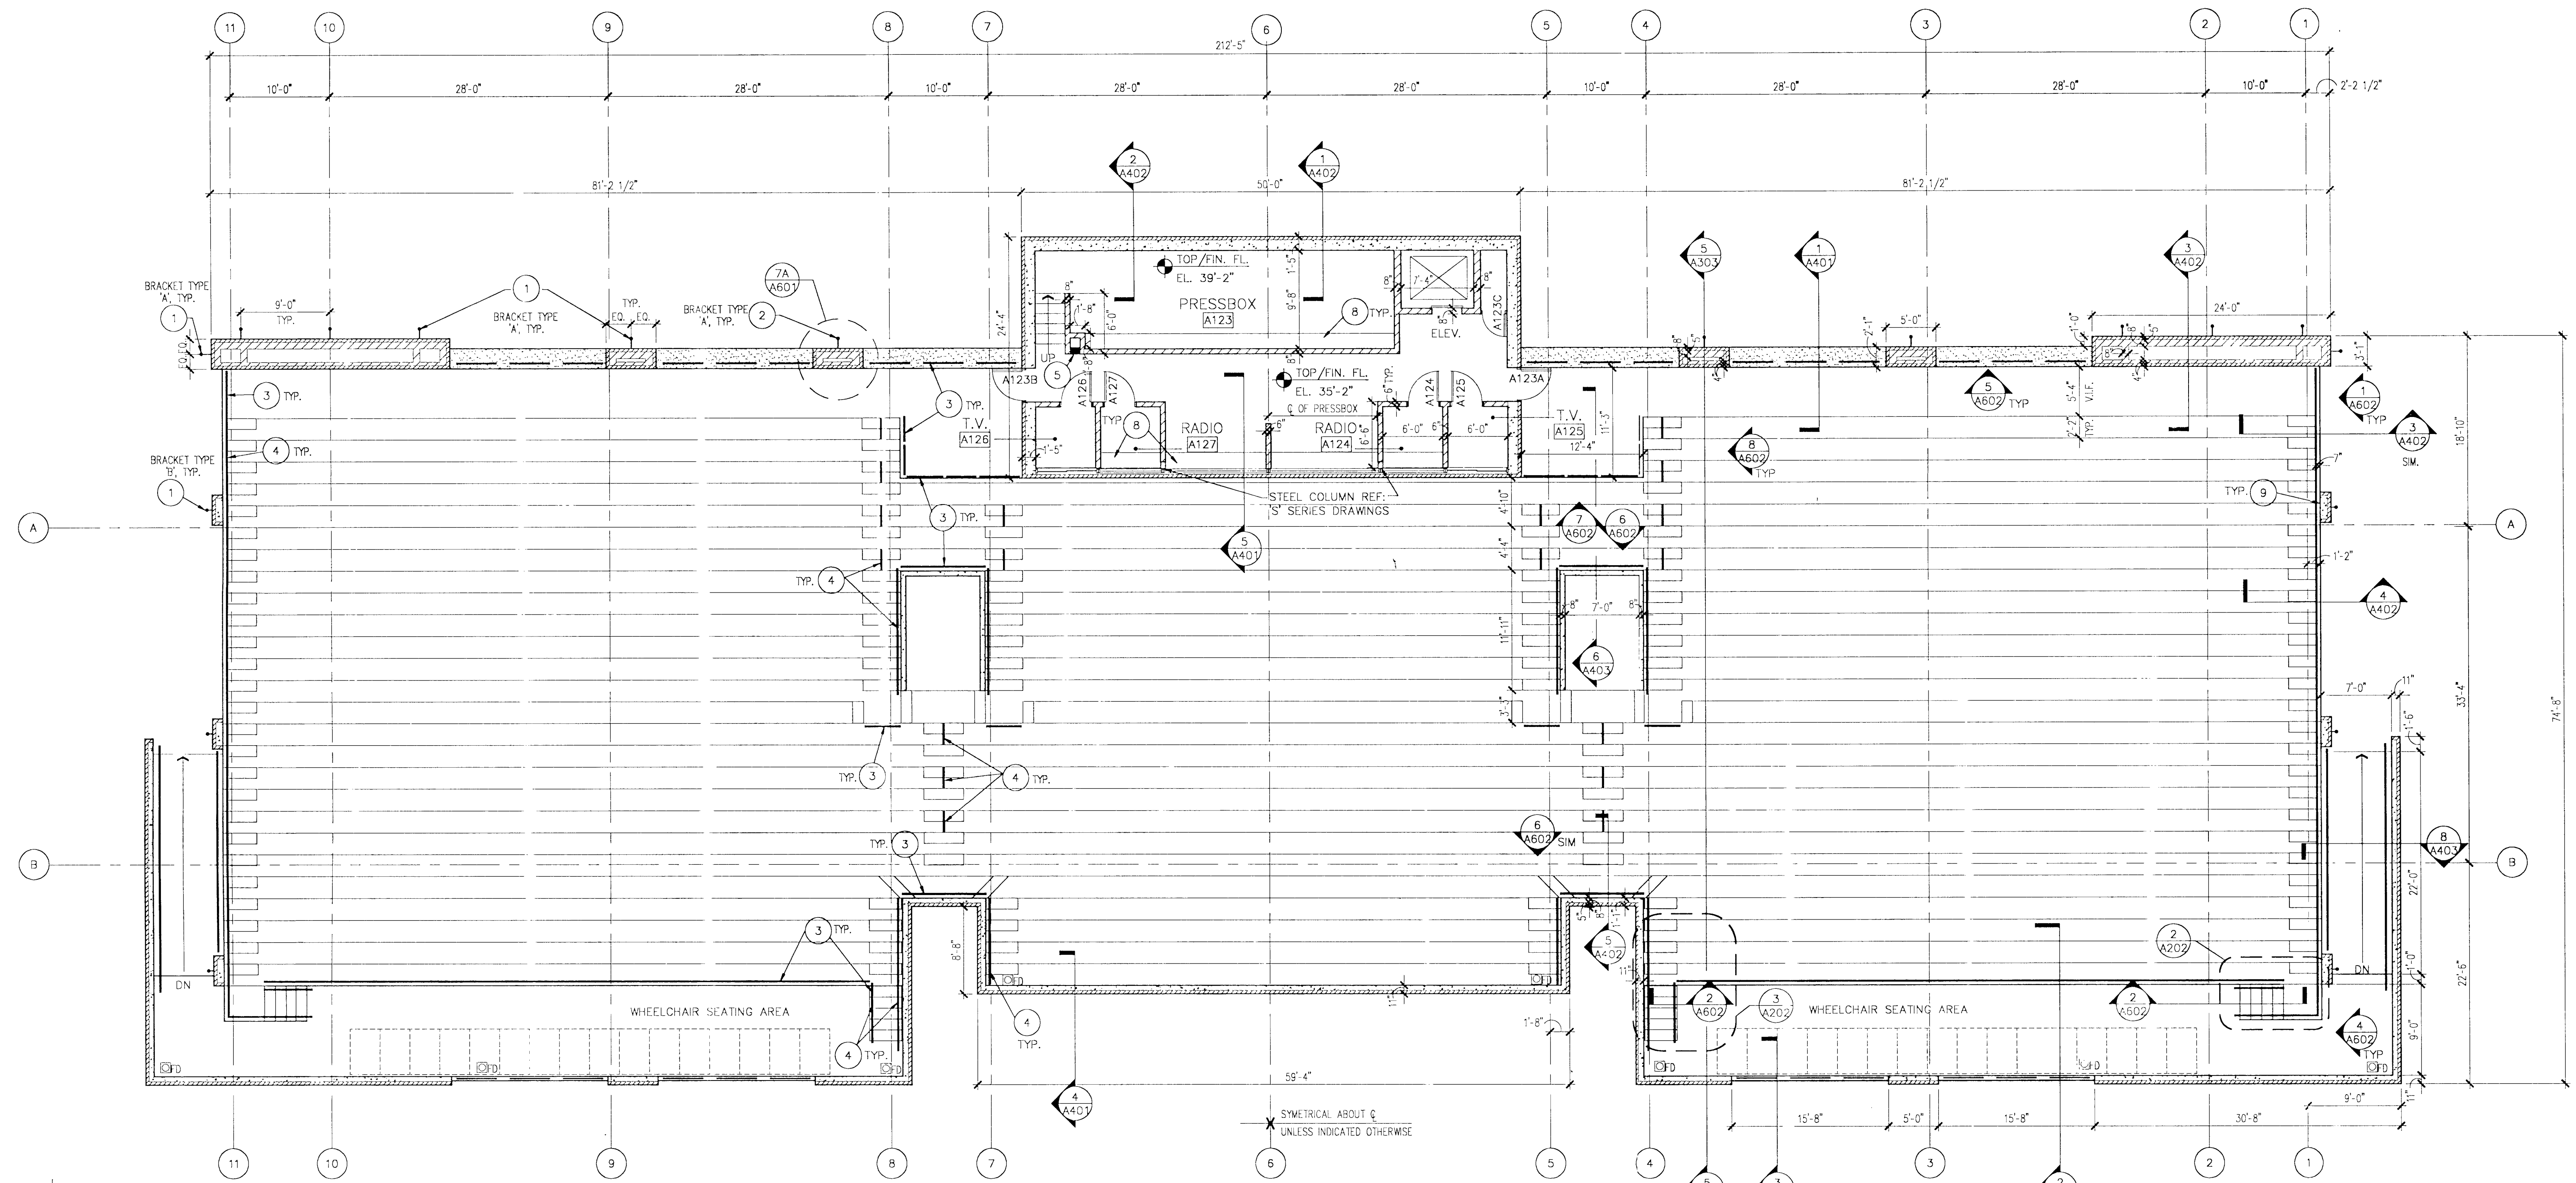


FOOTBALL STADIUM SEATING PLAN

SCALE: 1/8" = 1'-0"

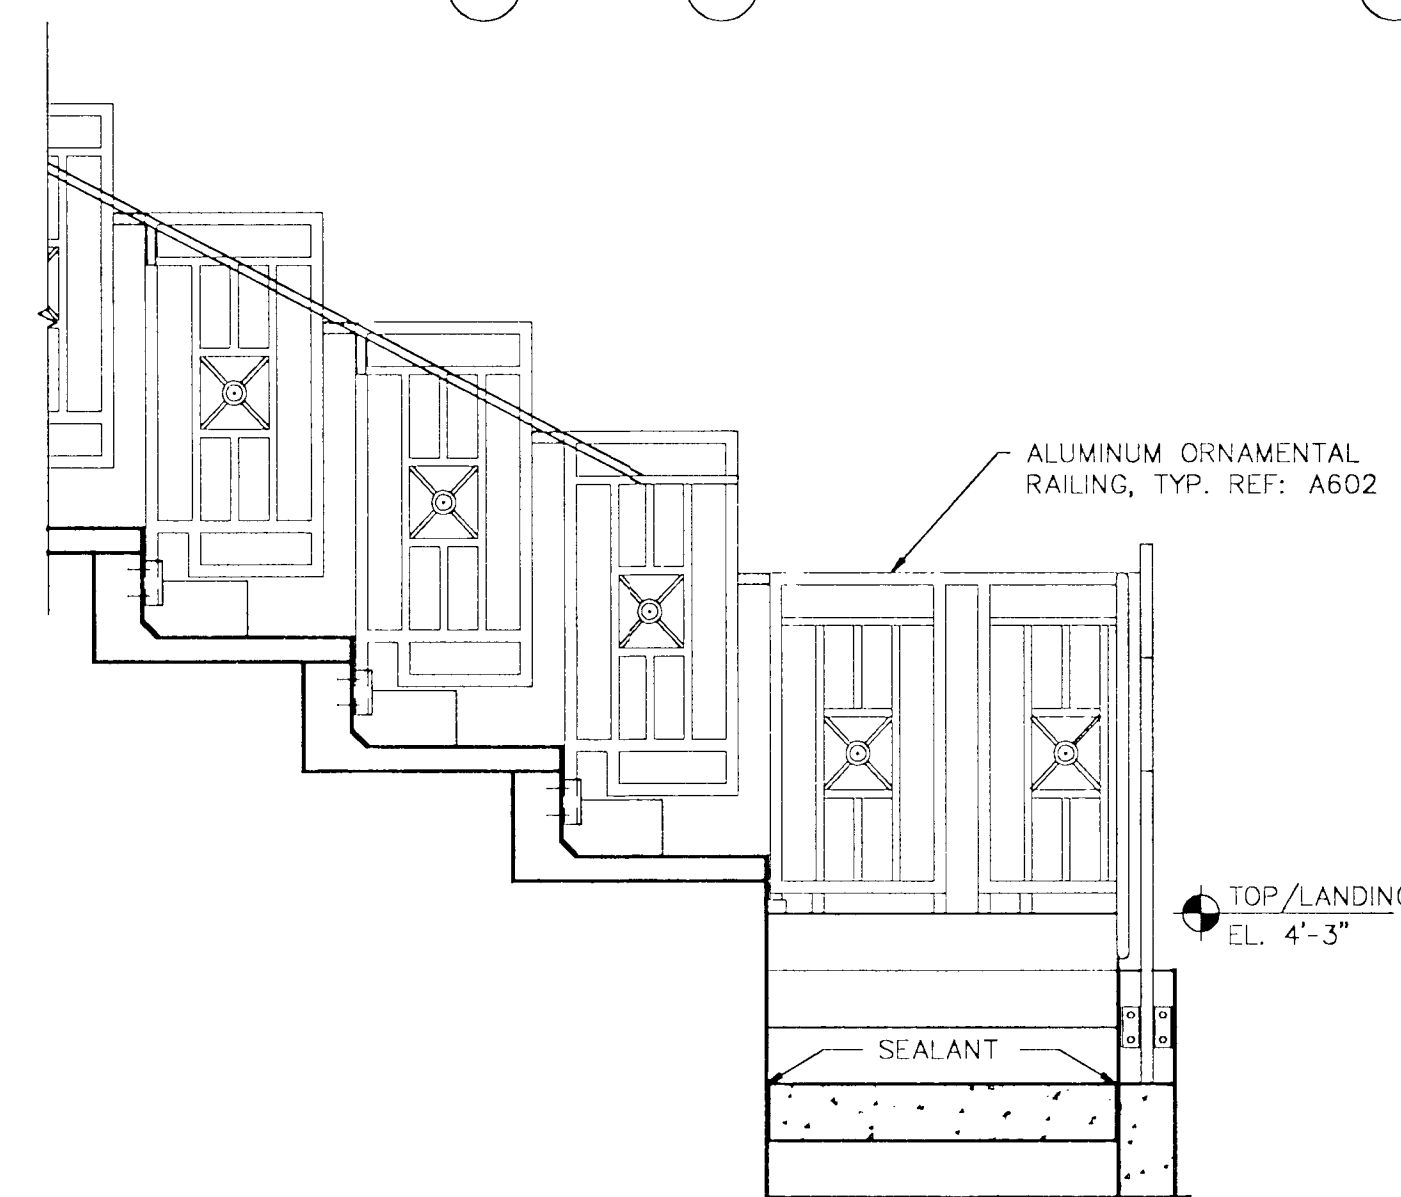

STAIR SECTION/ELEVATION

SCALE: 1/4" = 1'-0"

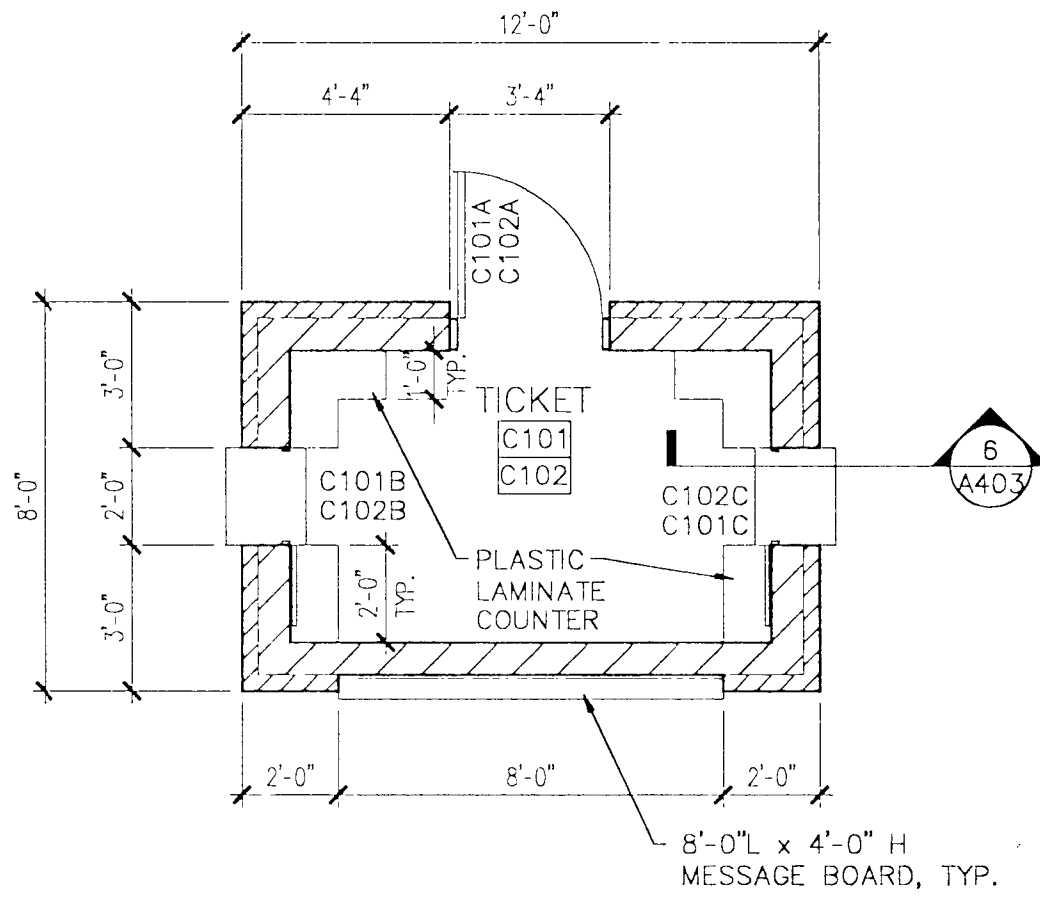

TYPICAL TICKET BOOTH


SCALE: 1/4" = 1'-0"

GENERAL PLAN NOTES

1. ALL WALL THICKNESSES ARE NOMINAL UNLESS INDICATED OTHERWISE.
2. ALL PRECAST STAIR TREADS TO HAVE SWIRL FINISH TO MATCH RISERS UNLESS INDICATED OTHERWISE.
3. WHERE NOT DIMENSIONED, LOCATE HINGE SIDE OF DOOR FRAME 4" FROM WALL PERPENDICULAR TO DOOR FRAME.
4. ALL JOINTS ARE TO BE SEALED TO MAKE THIS BUILDING WATERTIGHT (WHETHER SHOWN OR NOT).
5. REFERENCE STRUCTURAL DRAWINGS FOR CONTROL JOINT LOCATIONS.
6. ALL EXPOSED CORNERS OF CMU SHALL BE BULLNOSED.
7. PROVIDE BOND BEAM OR STEEL LINTEL OVER ALL OPENINGS IN MASONRY WALLS. SEE ARCHITECTURAL DOOR AND FRAME SCHEDULE FOR LINTEL SCHEDULE. SEE MECHANICAL DRAWINGS FOR SIZE AND LOCATION OF MECHANICAL OPENINGS.
8. FOR HEIGHT OF WALLS AND/OR PARTITIONS ABOVE FINISHED CEILING, AND WALLS WHICH EXTEND TO THE UNDERSIDE OF RISERS, REF: SHEET A204.
9. TYPICAL EXTERIOR WALLS ARE 8" PRECAST CONCRETE WALL PANELS W/ 4" FACE BRICK, ACTUAL WALL THICKNESS OF 1'-1". NO INSULATION NEED BE PROVIDED IN WALL SYSTEM.
10. WHERE CONCRETE WALL PANEL IS EXPOSED TO VIEW, SHOW STEEL FORM FINISH. WHERE BOTH SIDES ARE EXPOSED TO VIEW PROVIDE 'HROWEL' FINISH ON SECOND SIDE.
11. NOT USED.
12. SEE DETAIL 10/A603 FOR PERIMETER JOINTS AT WALLS WHICH PENETRATE THE FLOOR SLAB.
13. METAL LOCKERS REF: 13/A601.
14. METAL SIGNAGE SEE SHEET A604.

NUMBERED PLAN NOTES

1. 12'-0" ALUMINUM FLAGPOLE REF: 10/A601.
2. 18'-0" ALUMINUM FLAGPOLE REF: 10/A601.
3. ALUMINUM GUARDRAIL, REF: SHEET A602.
4. ALUMINUM HANDRAIL, REF: 5/A603.
5. FIRE EXTINGUISHER AND CABINET, REF: 12/A601.
6. FIRE EXTINGUISHER AND HOLDER.
7. NORMAL WEIGHT CMU, GROUT WALL FULL HEIGHT.
8. PLASTIC LAMINATE TOP, REF: 9/A603.
9. ARCHITECTURAL PRECAST PANEL, FINISH TO MATCH RISERS.
10. INDICATES A PRECAST CONCRETE OPENING AT HEAD HGT. 7'-5" A.F.F. THRESHOLD OR SILL TO BE -0'-0" A.F.F.
11. NOT USED.
12. SEE DETAIL 10/A603 FOR PERIMETER JOINTS AT WALLS WHICH PENETRATE THE FLOOR SLAB.
13. METAL LOCKERS REF: 13/A601.
14. METAL SIGNAGE SEE SHEET A604.

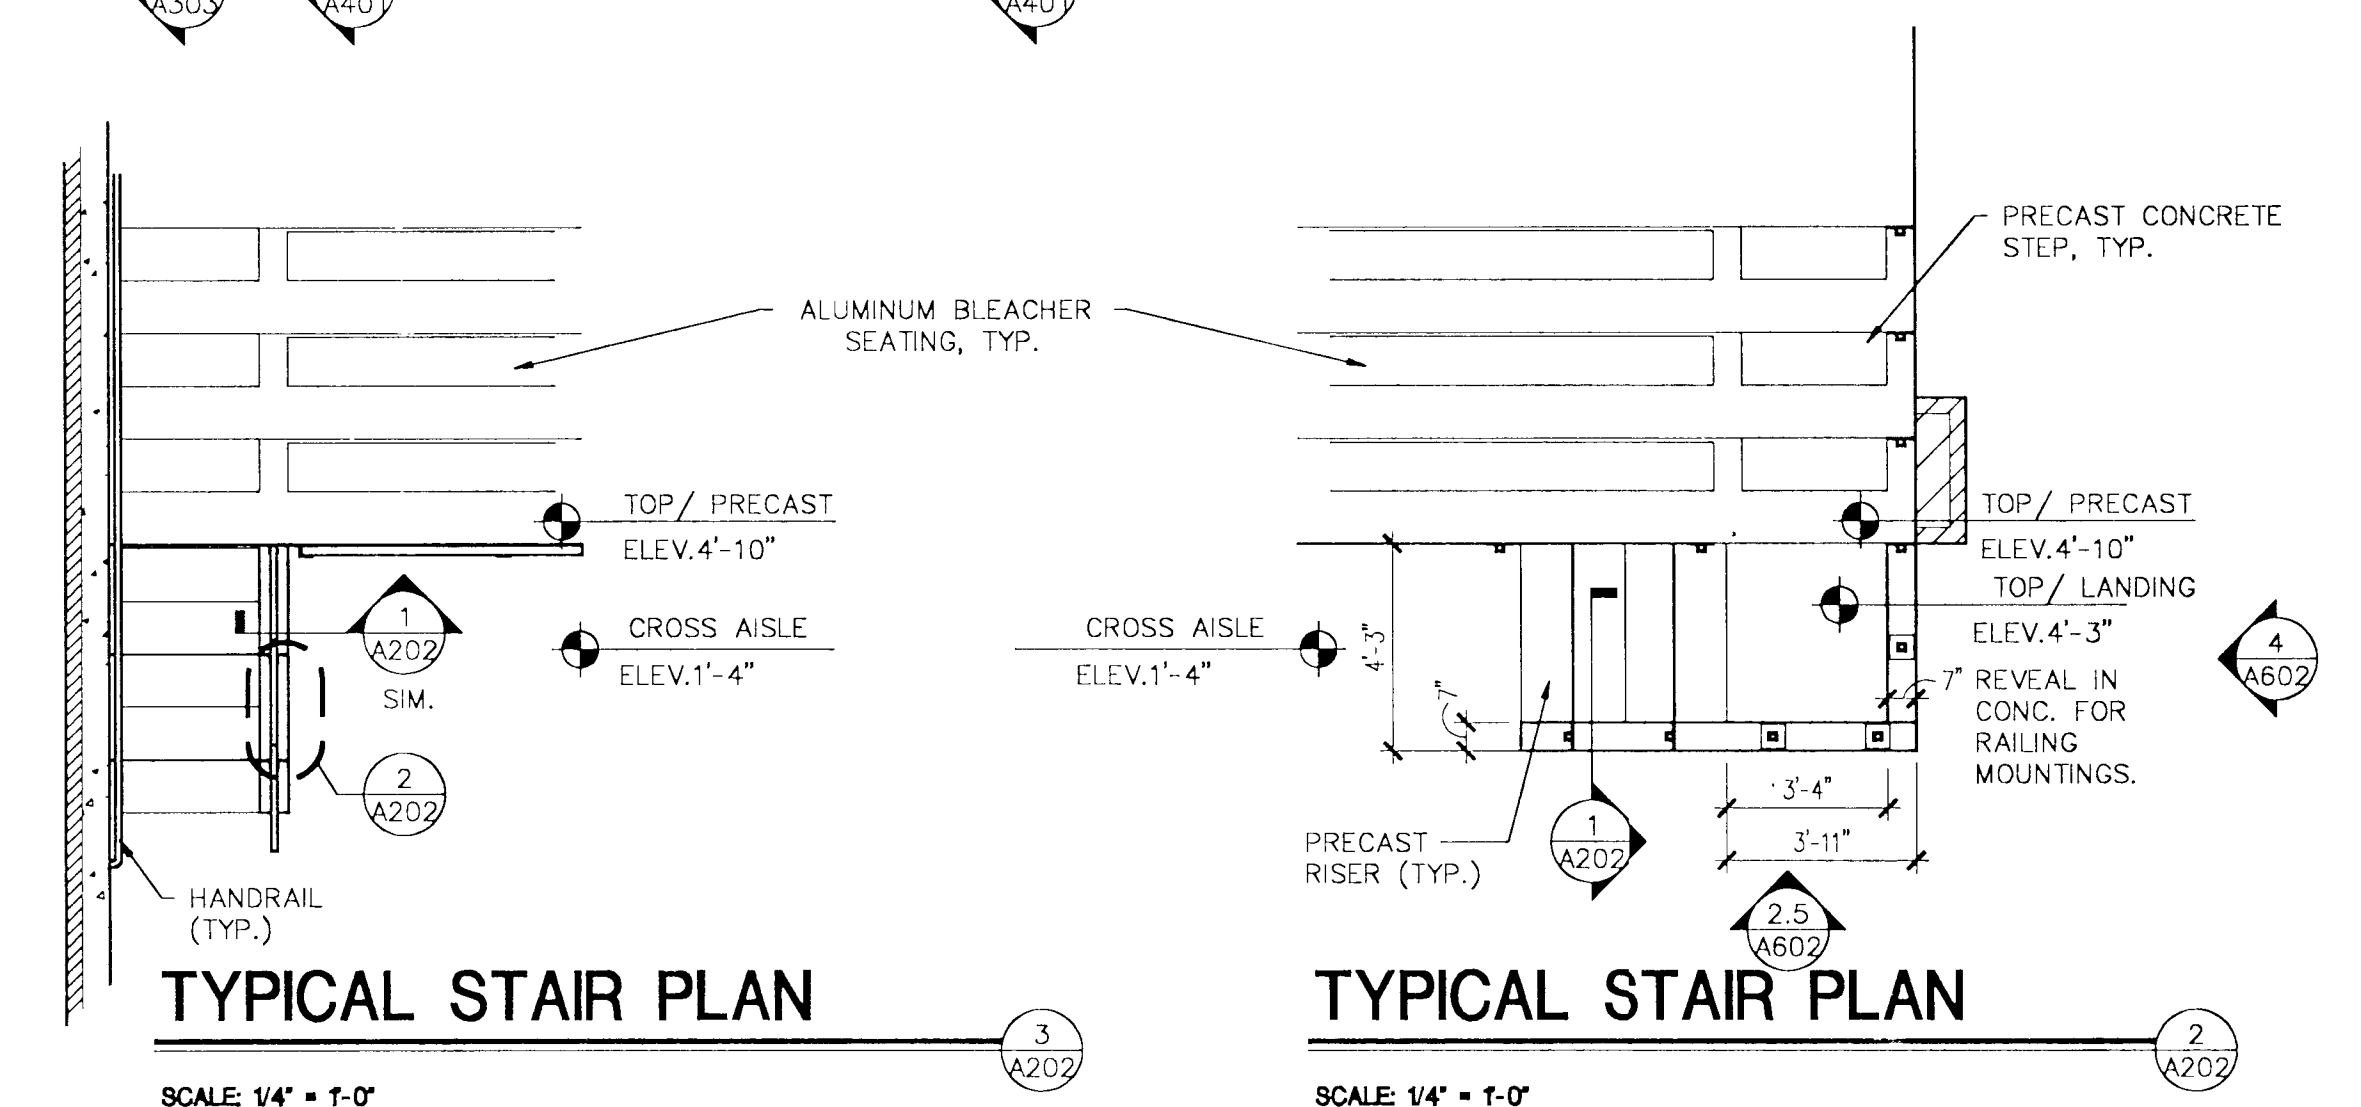


TYPICAL STAIR PLAN

SCALE: 1/4" = 1'-0"

TYPICAL STAIR PLAN

SCALE: 1/4" = 1'-0"

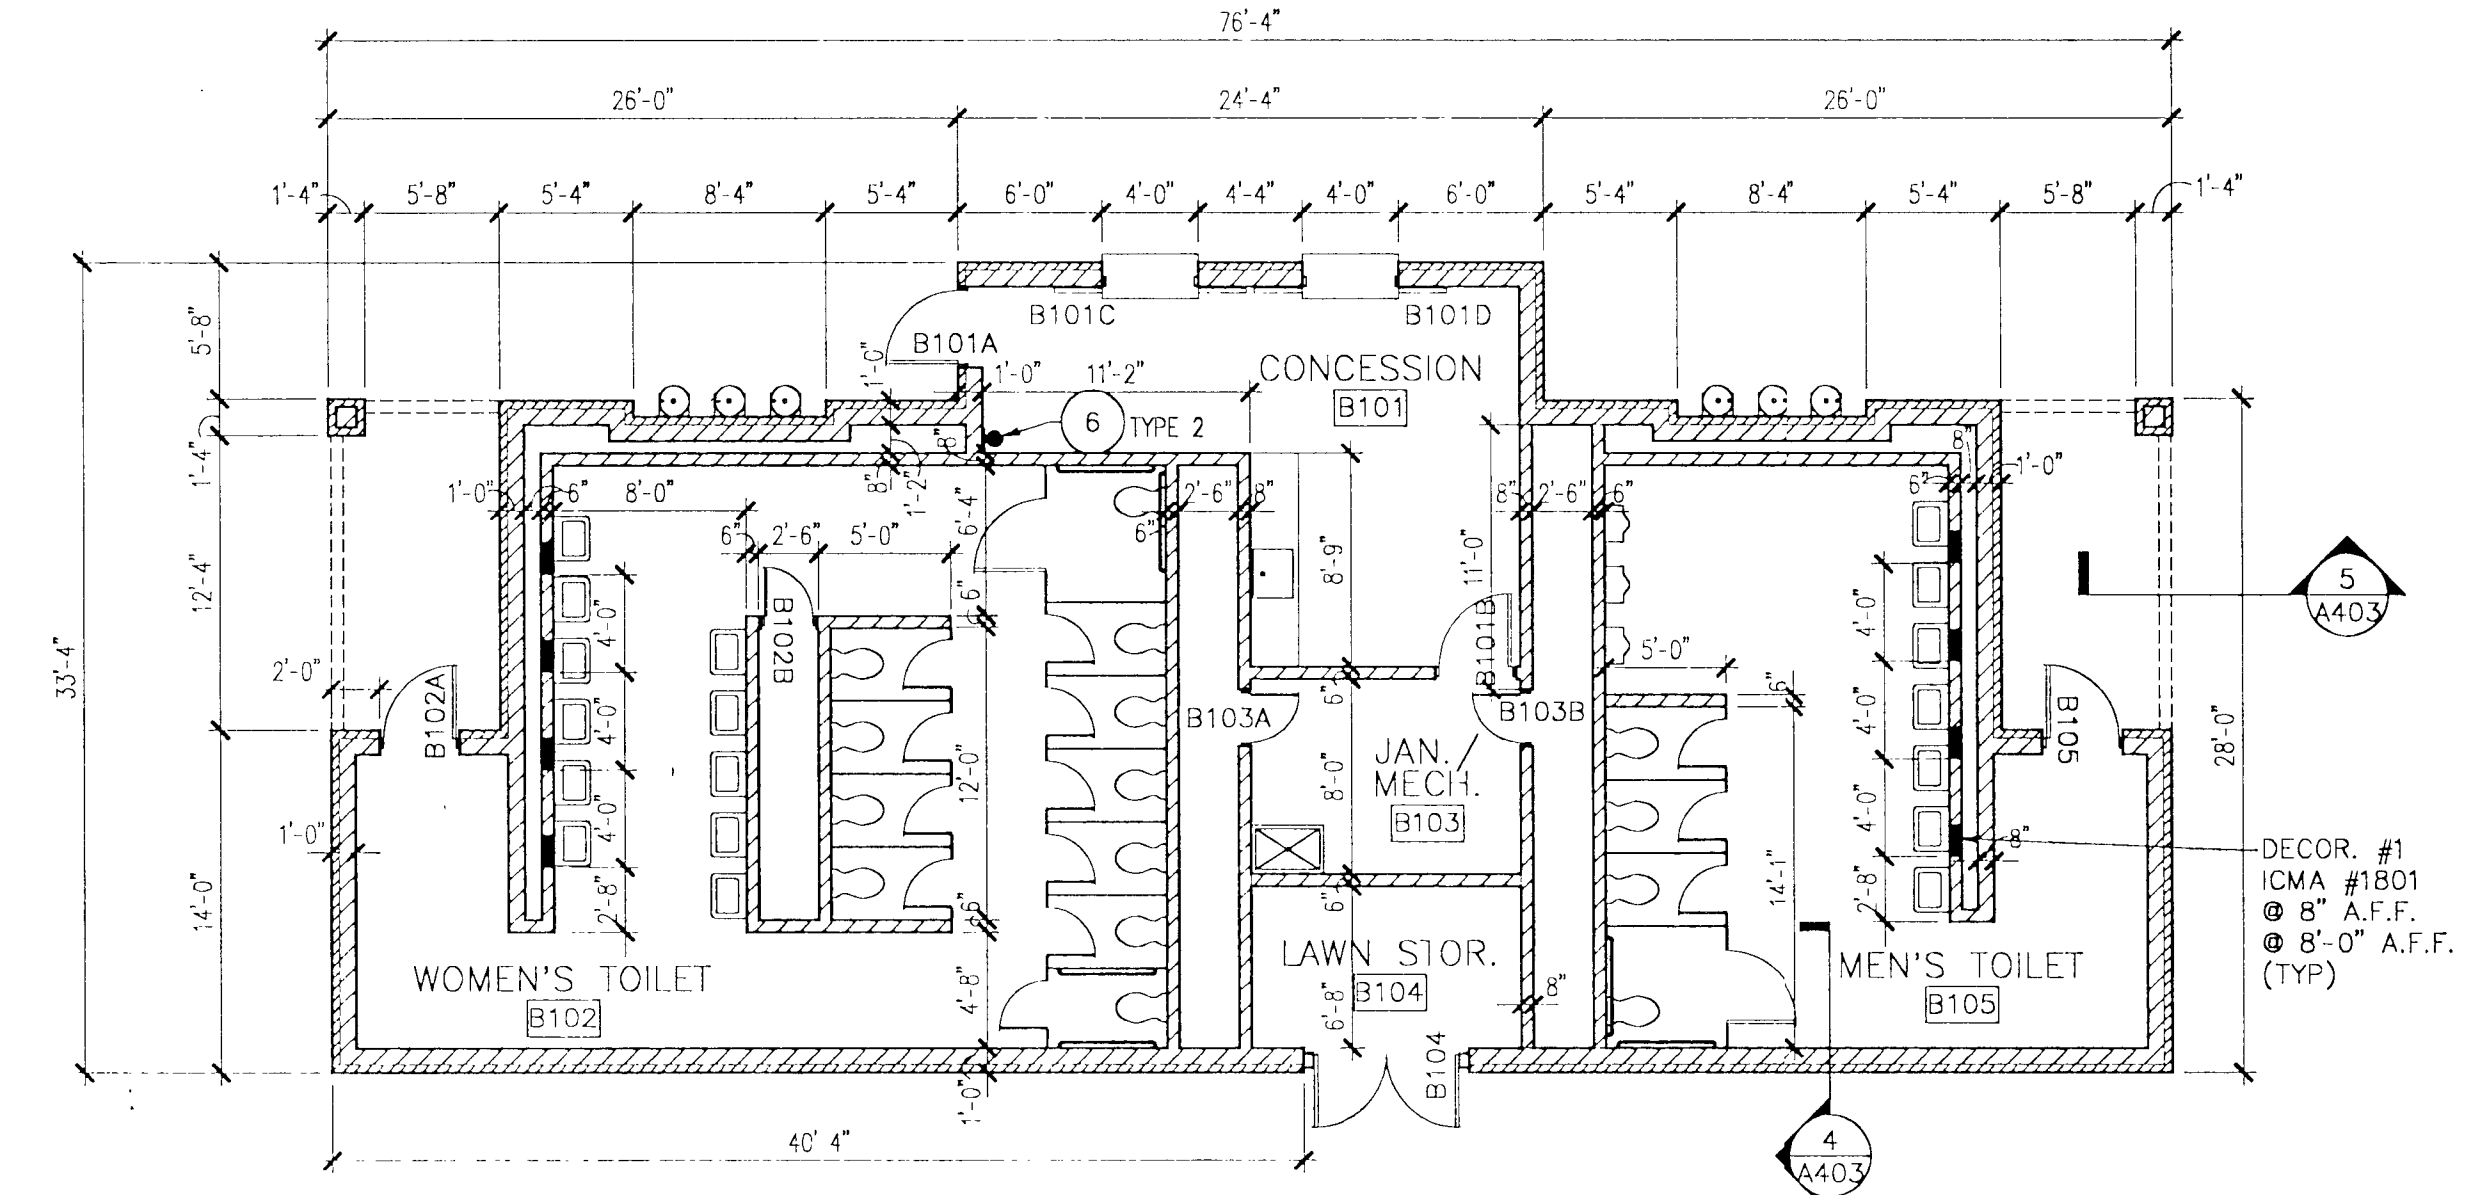


VISITOR TOILET & CONCESSION

SCALE: 1/8" = 1'-0"



NOTE: REF: 3/A204 FOR PLAN ENLARGEMENT

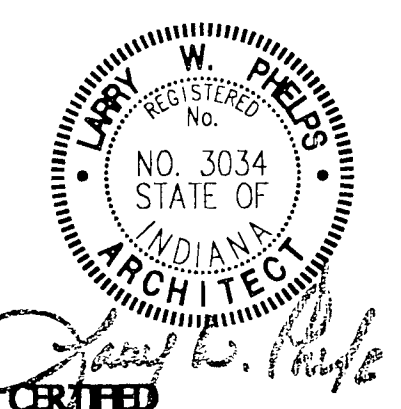

THE ODLE MCGUIRE & SHOOK CORPORATION
ARCHITECTURE • ENGINEERING • LANDSCAPE ARCHITECTURE • INTERIOR DESIGN
6786 NORTH STATE ROAD 37, POST OFFICE BOX 2148, BLOOMINGTON, INDIANA 47402, 812/676-2020
8275 ALISON POINTE TRAIL, POST OFFICE BOX 50428, INDIANAPOLIS, INDIANA 46250, 317/842-0000


REVISIONS

© Copyright 1994 by THE ODLE MCGUIRE & SHOOK CORPORATION. Copyright includes architectural work, building design, plans or drawings, and specifications. Architectural work is the overall form as well as the arrangement and composition of space and elements in the design. Reproduction without written permission is prohibited.

MICHIGAN CITY SPORTS COMPLEX
AMES FIELD
MICHIGAN CITY, INDIANA


PROJECT NO. 93052
DATE: MAY 31, 1994
drawn by: MRM
checked by: GKJ

A202
FLOOR PLANS
GRANDSTAND SEATING
VISITOR TOILET/CONCESSION
TICKET BOOTH

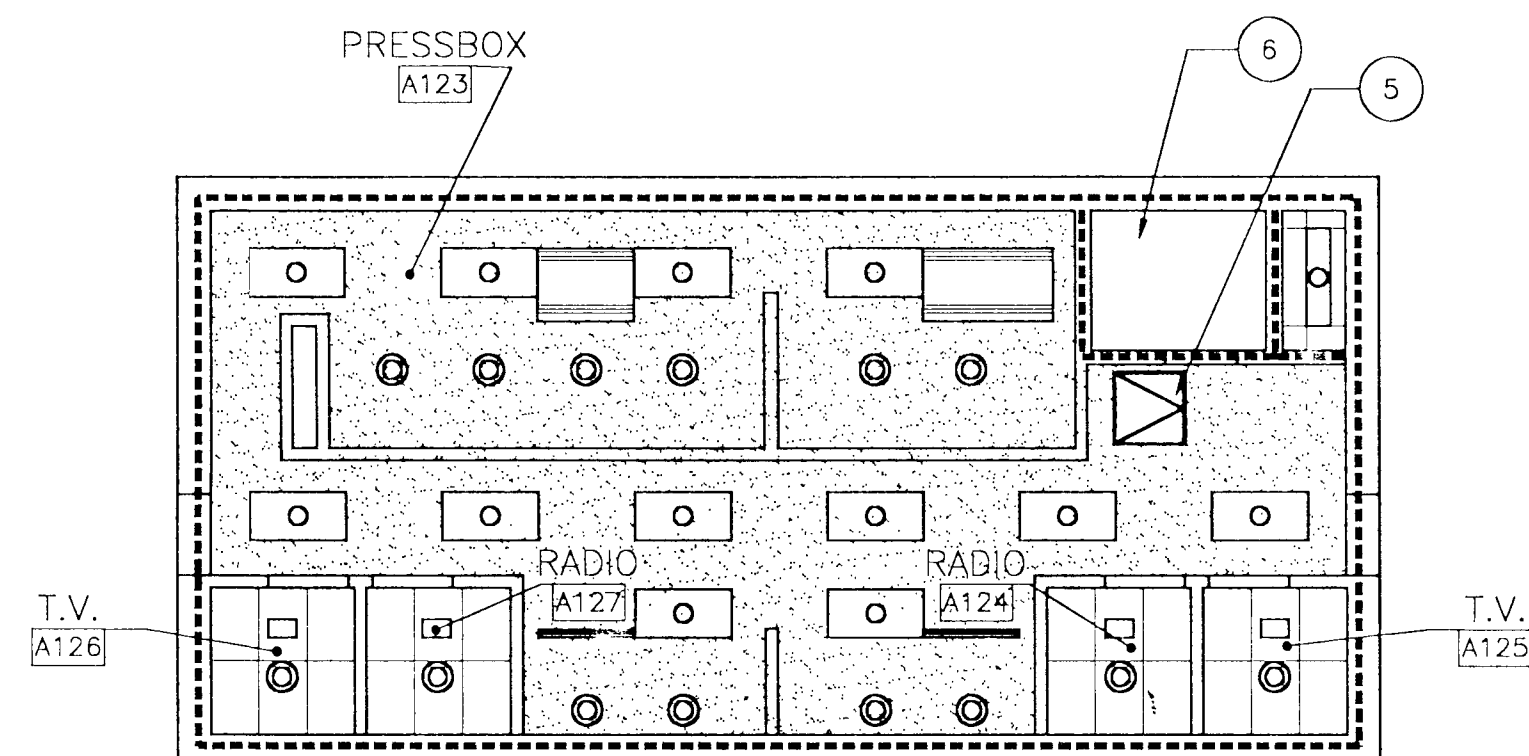


**PRESSBOX
REFLECTED CEILING PLAN**

SCALE 1/8" = 1'-0"

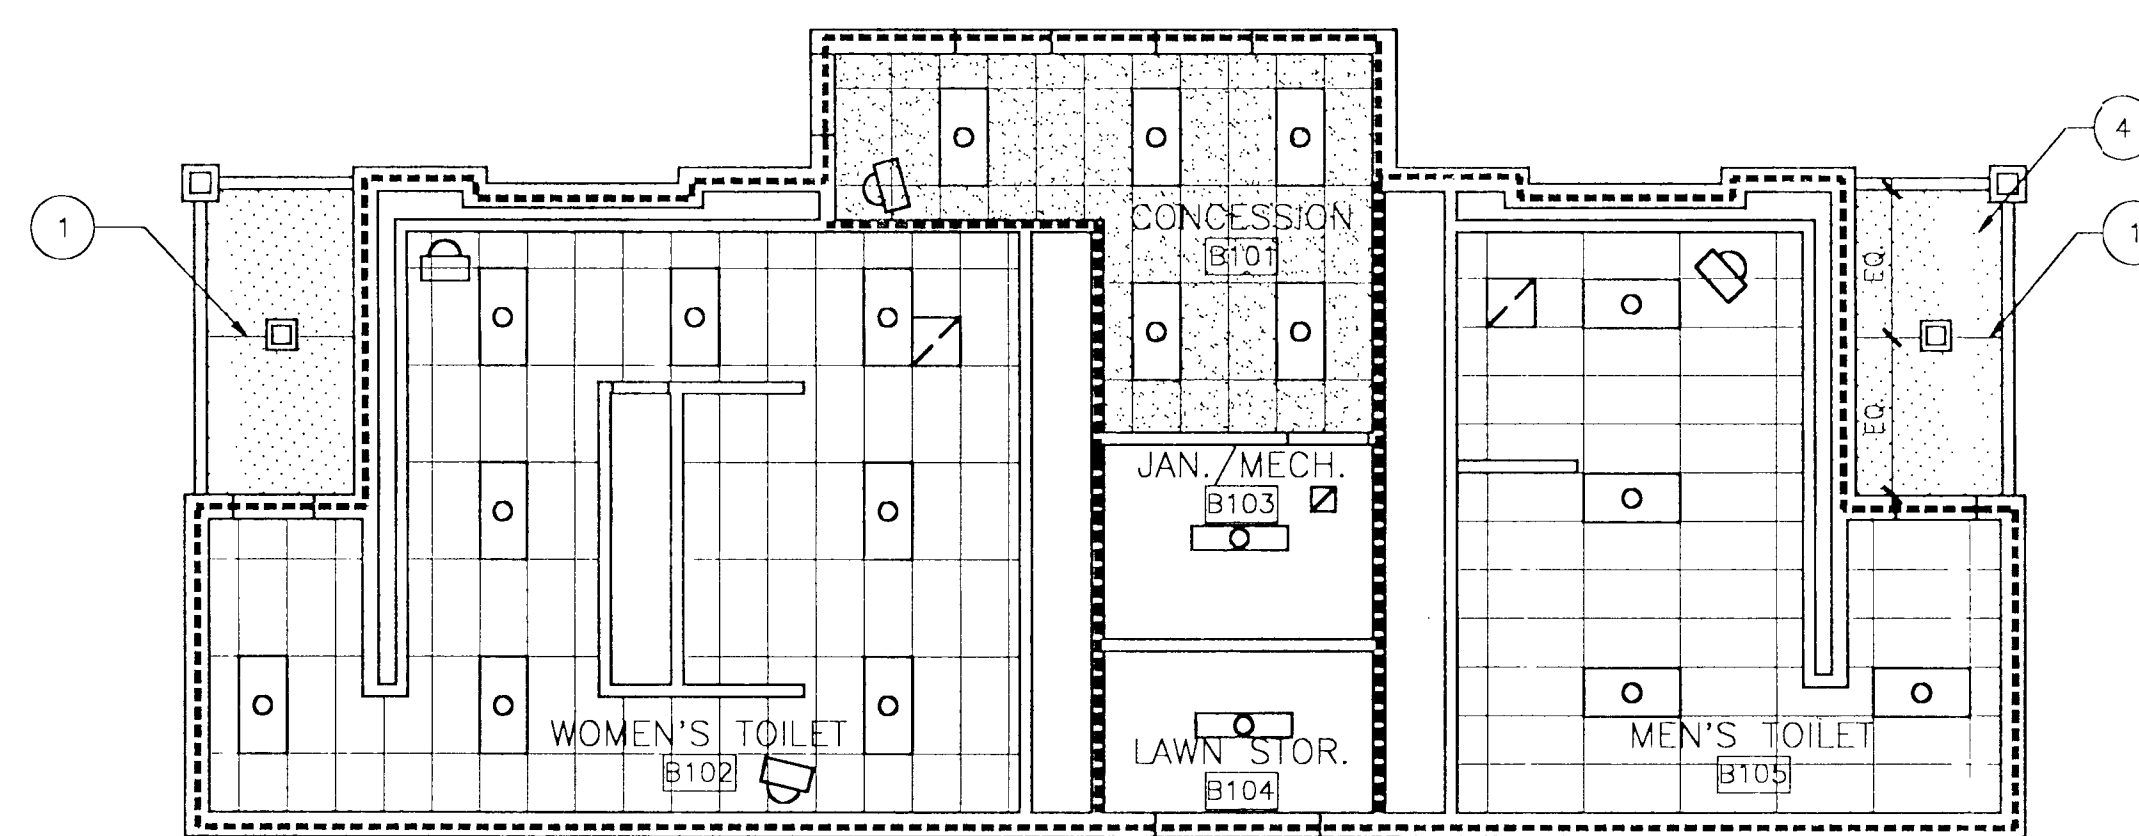

**VISITOR TOILET & CONCESSION
REFLECTED CEILING PLAN**

SCALE 1/8" = 1'-0"

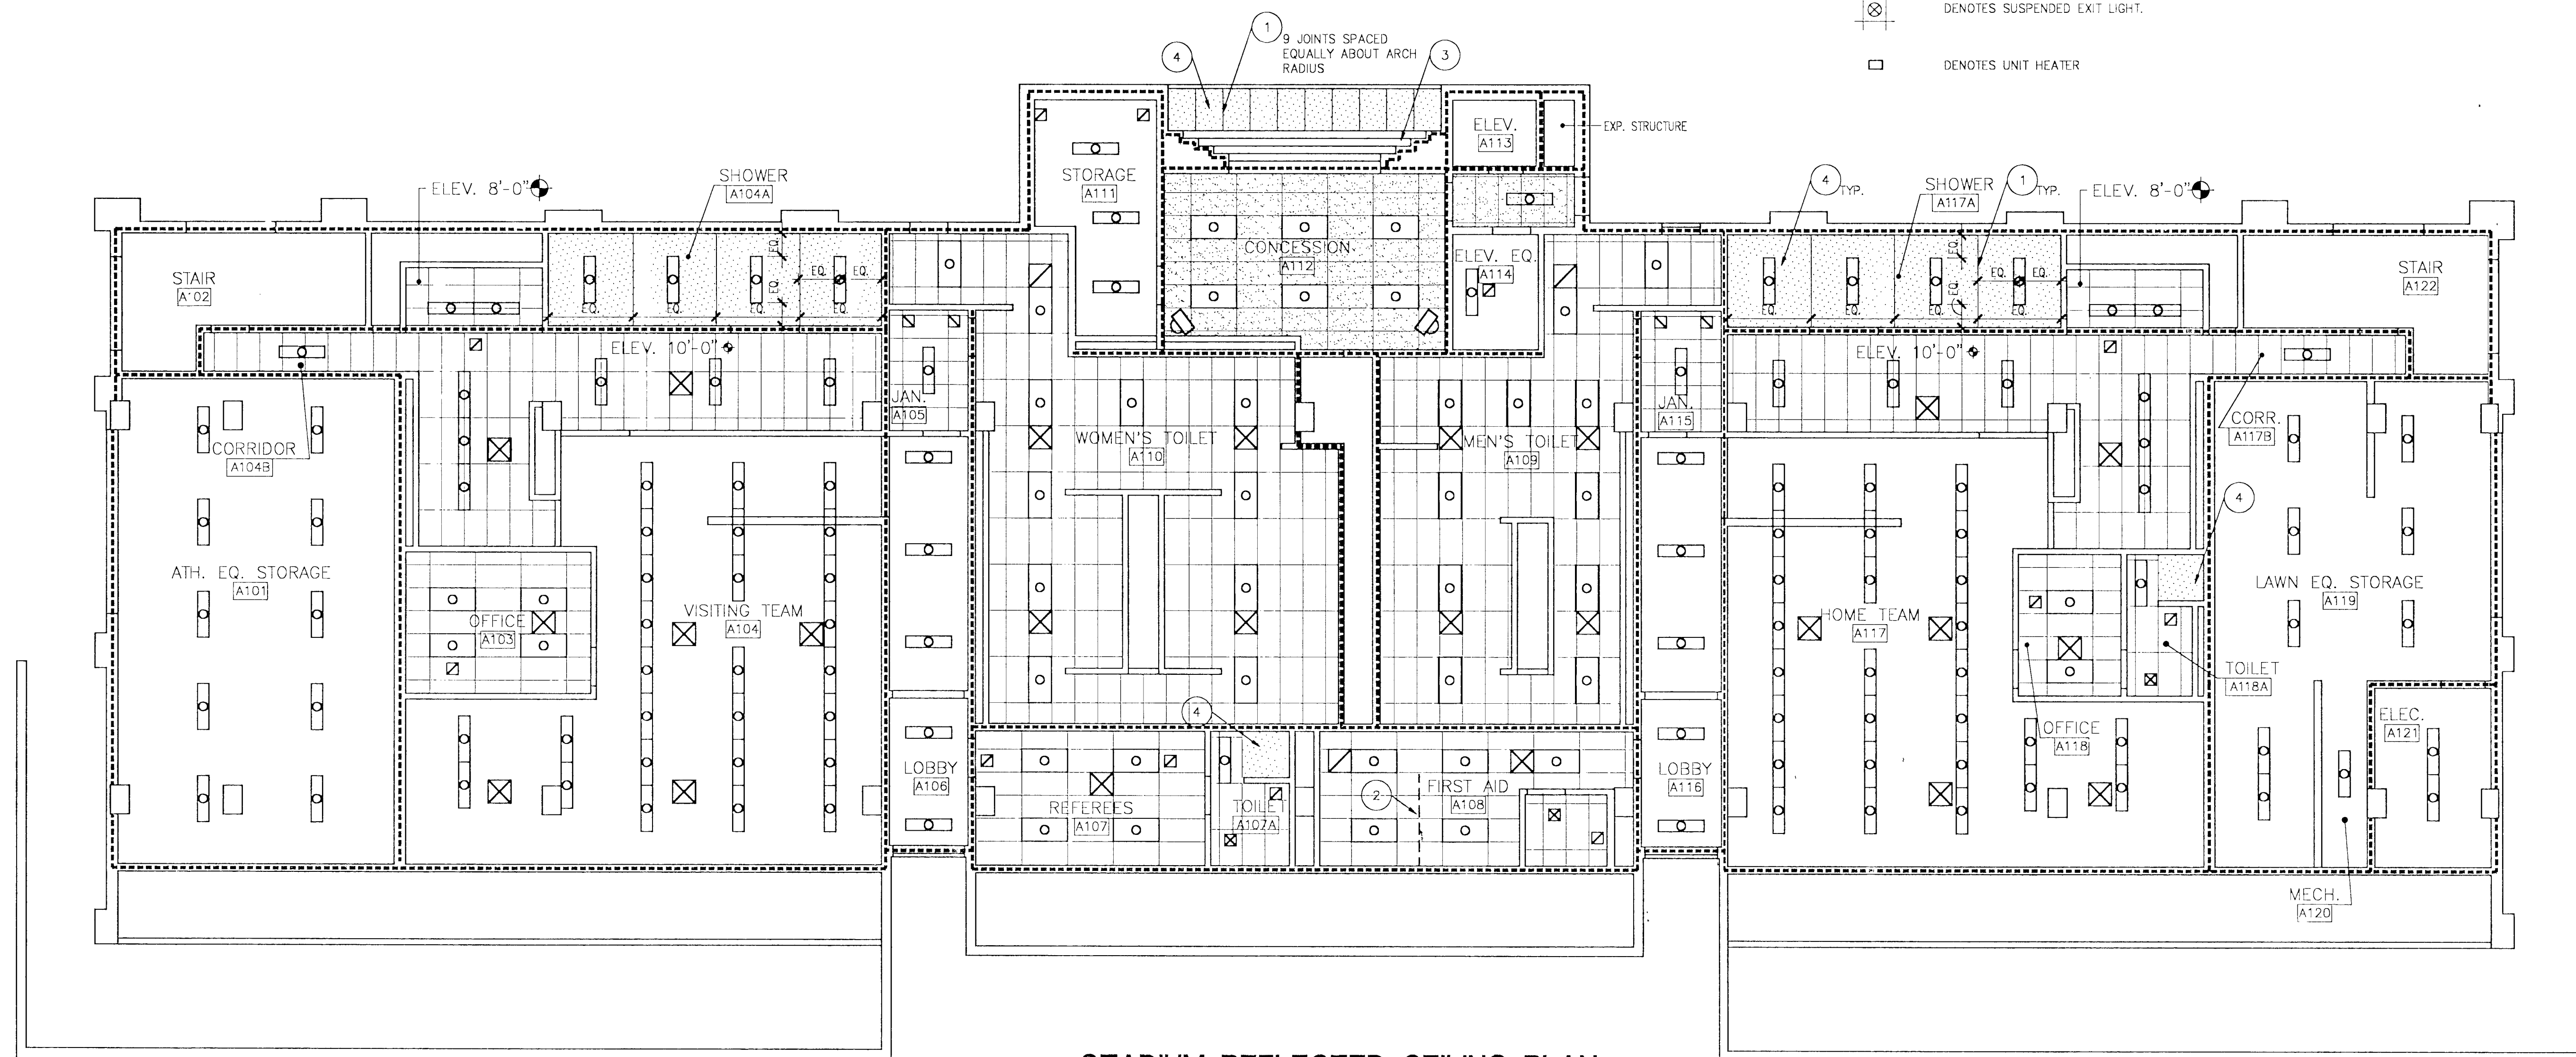

STADIUM REFLECTED CEILING PLAN

SCALE 1/8" = 1'-0"

NORTH



GENERAL NOTES


1. ALL WALLS NOT GOING TO STRUCTURE ABOVE SHALL TERMINATE NO LESS THAN 8" ABOVE FINISH CEILING. AT CMU WALLS, MAINTAIN COURSING AND PROVIDE BOND BEAM AT TOP OF WALLS.
2. PROVIDE SOUND TIGHT SEALS AT ALL WALLS EXTENDING TO STRUCTURE AND AT ALL WALL PENETRATIONS ABOVE CEILING LINE.
3. REFLECTED CEILING PLANS INDICATE GENERAL INTENT FOR SUSPENDED CEILINGS WITH RESPECT TO THE TILE/GRID LAYOUTS, ALIGNMENTS AND SIMILAR FEATURES. VERIFY ALL LAYOUTS IN FIELD AND NOTIFY ARCHITECT IN WRITING OF DISCREPANCIES PRIOR TO STARTING THE WORK.
4. REFERENCE MECHANICAL AND ELECTRICAL DRAWINGS FOR TYPES OF DIFFUSERS, LIGHTING FIXTURES, SPEAKERS, ETC. PROVIDE CUTOUTS IN THE TILE AS REQUIRED TO FACILITATE ALL INSTALLATIONS.

NUMBERED PLAN NOTES

1. CONTROL JOINT.
2. CUBICLE CURTAIN PARTITION TRACK.
3. BRICK CORBELING, REF. 2/A402.
4. CEMENT PLASTER CEILING, SEALANT AT PERIMETER, TYP.
5. ACCESS PANEL 3'-0" X 3'-0".
6. CONCRETE PANEL.

REFLECTED CEILING LEGEND

	DENOTES SUSPENDED ACOUSTICAL CEILING SYSTEM.		DENOTES SPEAKER.
	DENOTES SUSPENDED VINYL FACED GYPSUM DRYWALL PANEL CEILING SYSTEM.		DENOTES SMOKE DETECTOR.
	DENOTES SUSPENDED GYPSUM DRYWALL CEILING OR BULKHEAD.		DENOTES FIRE ALARM DEVICE.
	DENOTES SUSPENDED PLASTER CEILING OR BULKHEAD.		DENOTES MECHANICAL SYSTEM SUPPLY AIR DIFFUSER.
	DENOTES RECESSED 1'-0" X 4'-0" FLUORESCENT LIGHT FIXTURE.		DENOTES MECHANICAL SYSTEM RETURN OR EXHAUST AIR GRILLE.
	DENOTES RECESSED 2'-0" X 4'-0" FLUORESCENT LIGHT FIXTURE.		DENOTES MECHANICAL SYSTEM LINEAR SLOT DIFFUSER.
	DENOTES FLUORESCENT DOWNLIGHT.		DENOTES WALL TIGHT TO DECK SEAL WITH INSULATION.
	DENOTES H.I.D. DOWNLIGHT.		DENOTES SUSPENDED UNIT HEATER.
	DENOTES INCANDESCENT DOWNLIGHT.		DENOTES CABINET UNIT HEATER.
	DENOTES SUSPENDED EXIT LIGHT.		
	DENOTES UNIT HEATER.		

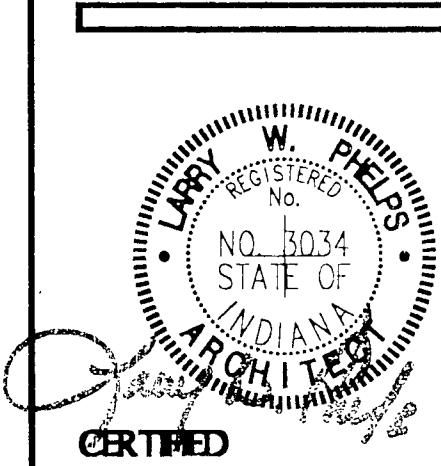

THE ODLE MCGUIRE & SHOOK CORPORATION
ARCHITECTURE • ENGINEERING • LANDSCAPE ARCHITECTURE • INTERIOR DESIGN
8275 ALISON PONTE TRAIL, POST OFFICE BOX 50428, INDIANAPOLIS, INDIANA 46250, 317/842-0000

REVISIONS

© Copyright 1994 by THE ODLE MCGUIRE & SHOOK CORPORATION. Copyright includes architectural work, building design plans or drawings, and specifications. Architectural work is the result of the design and construction of the design. Reproduction without written permission is prohibited.

MICHIGAN CITY SPORTS COMPLEX
AMES FIELD
MICHIGAN CITY, INDIANA


PROJECT NO. 93052
DATE MAY 31, 1994
drawn by: MRM/MCW
checked by: GKJ

A203
REFLECTIVE CEILING PLANS

TOILET ACCESSORY SCHEDULE					
ITEM	DESCRIPTION	MOUNTING HEIGHT TO TOP OF HANDLE	HEIGHTS TO TOP OF HANDLE	REMARKS	BOBRICK MODEL NO.
T1	TISSUE DISPENSER/ NAPKIN DISPOSAL	38"	-	TWO COMPARTMENT RECESSED	B-3570
T2	TISSUE DISPENSER/ NAPKIN DISPOSAL	34"	-	TWO COMPARTMENT RECESSED	B-35701.6
T3	TISSUE DISPENSER	38"	-	ONE COMPARTMENT TWIN ROLL/SURF.MT.	B-2892
T4	TISSUE DISPENSER	38"	-	TWO COMPARTMENT RECESSED	B-366
T5	TISSUE DISPENSER	38"	-	ONE COMPARTMENT MULTI-ROLL/SURF.MT.	B-268
T5A	TISSUE DISPENSER/ NAPKIN DISPOSAL	34"	-	ONE COMPARTMENT MULTI-ROLL/RECESS.	B-35704.6
T6	MIRROR	40"/BOT.	-	24" W.	B-1556
T7	GRAB BAR	34" @	-	42" L.	B-6806
T8	GRAB BAR	34" @	-	36" L.	B-6806
T9	SOAP DISPENSER	38"	-	RECESSED	B-4063
T10	NAPKIN/TAMPON VENDOR	38"-40" TO COIN SLOT	-	DOUBLE COIN MECHANISMS	B-43500
T11	TOWEL DISPENSER/ WASTE RECEPTACLE	35" TOP OF HANDLE	-	RECESSED	B-39603
T11A	TOWEL DISPENSER/ WASTE RECEPTACLE	35" TOP OF HANDLE	-	SURFACE MOUNT	B-396034
T12	MOP/BROOM HOLDER	60"	-	W/ UTILITY SHELF	B-224
T13	TOWEL PIN	40" @	-		B-677
T14	SHOWER CURTAIN AND ROD	72"	-		B-6047 B-204-1


GENERAL TOILET ROOM NOTES

- REFER TO TYP. STALL ELEVATIONS FOR DIMENSIONS WITHIN STALLS FOR TOILET ACCESSORIES.
- REFERENCE PLUMBING DRAWINGS FOR FLOOR DRAIN ELEVATIONS.

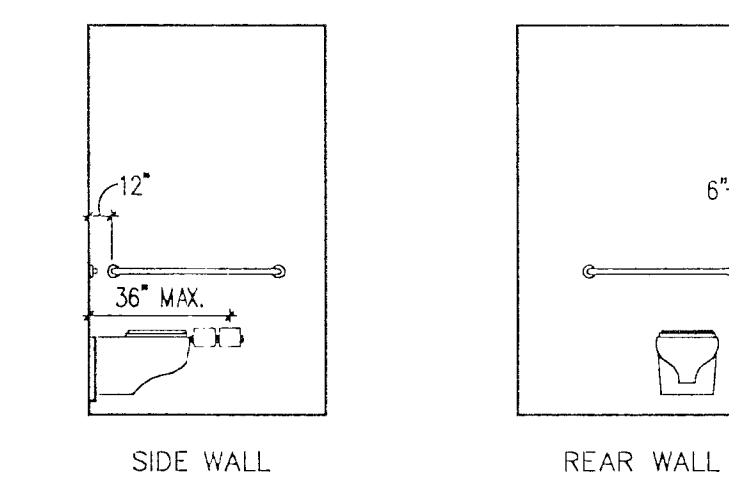


TYP. STALL ELEVATIONS

SCALE 1/4" = 1'-0"

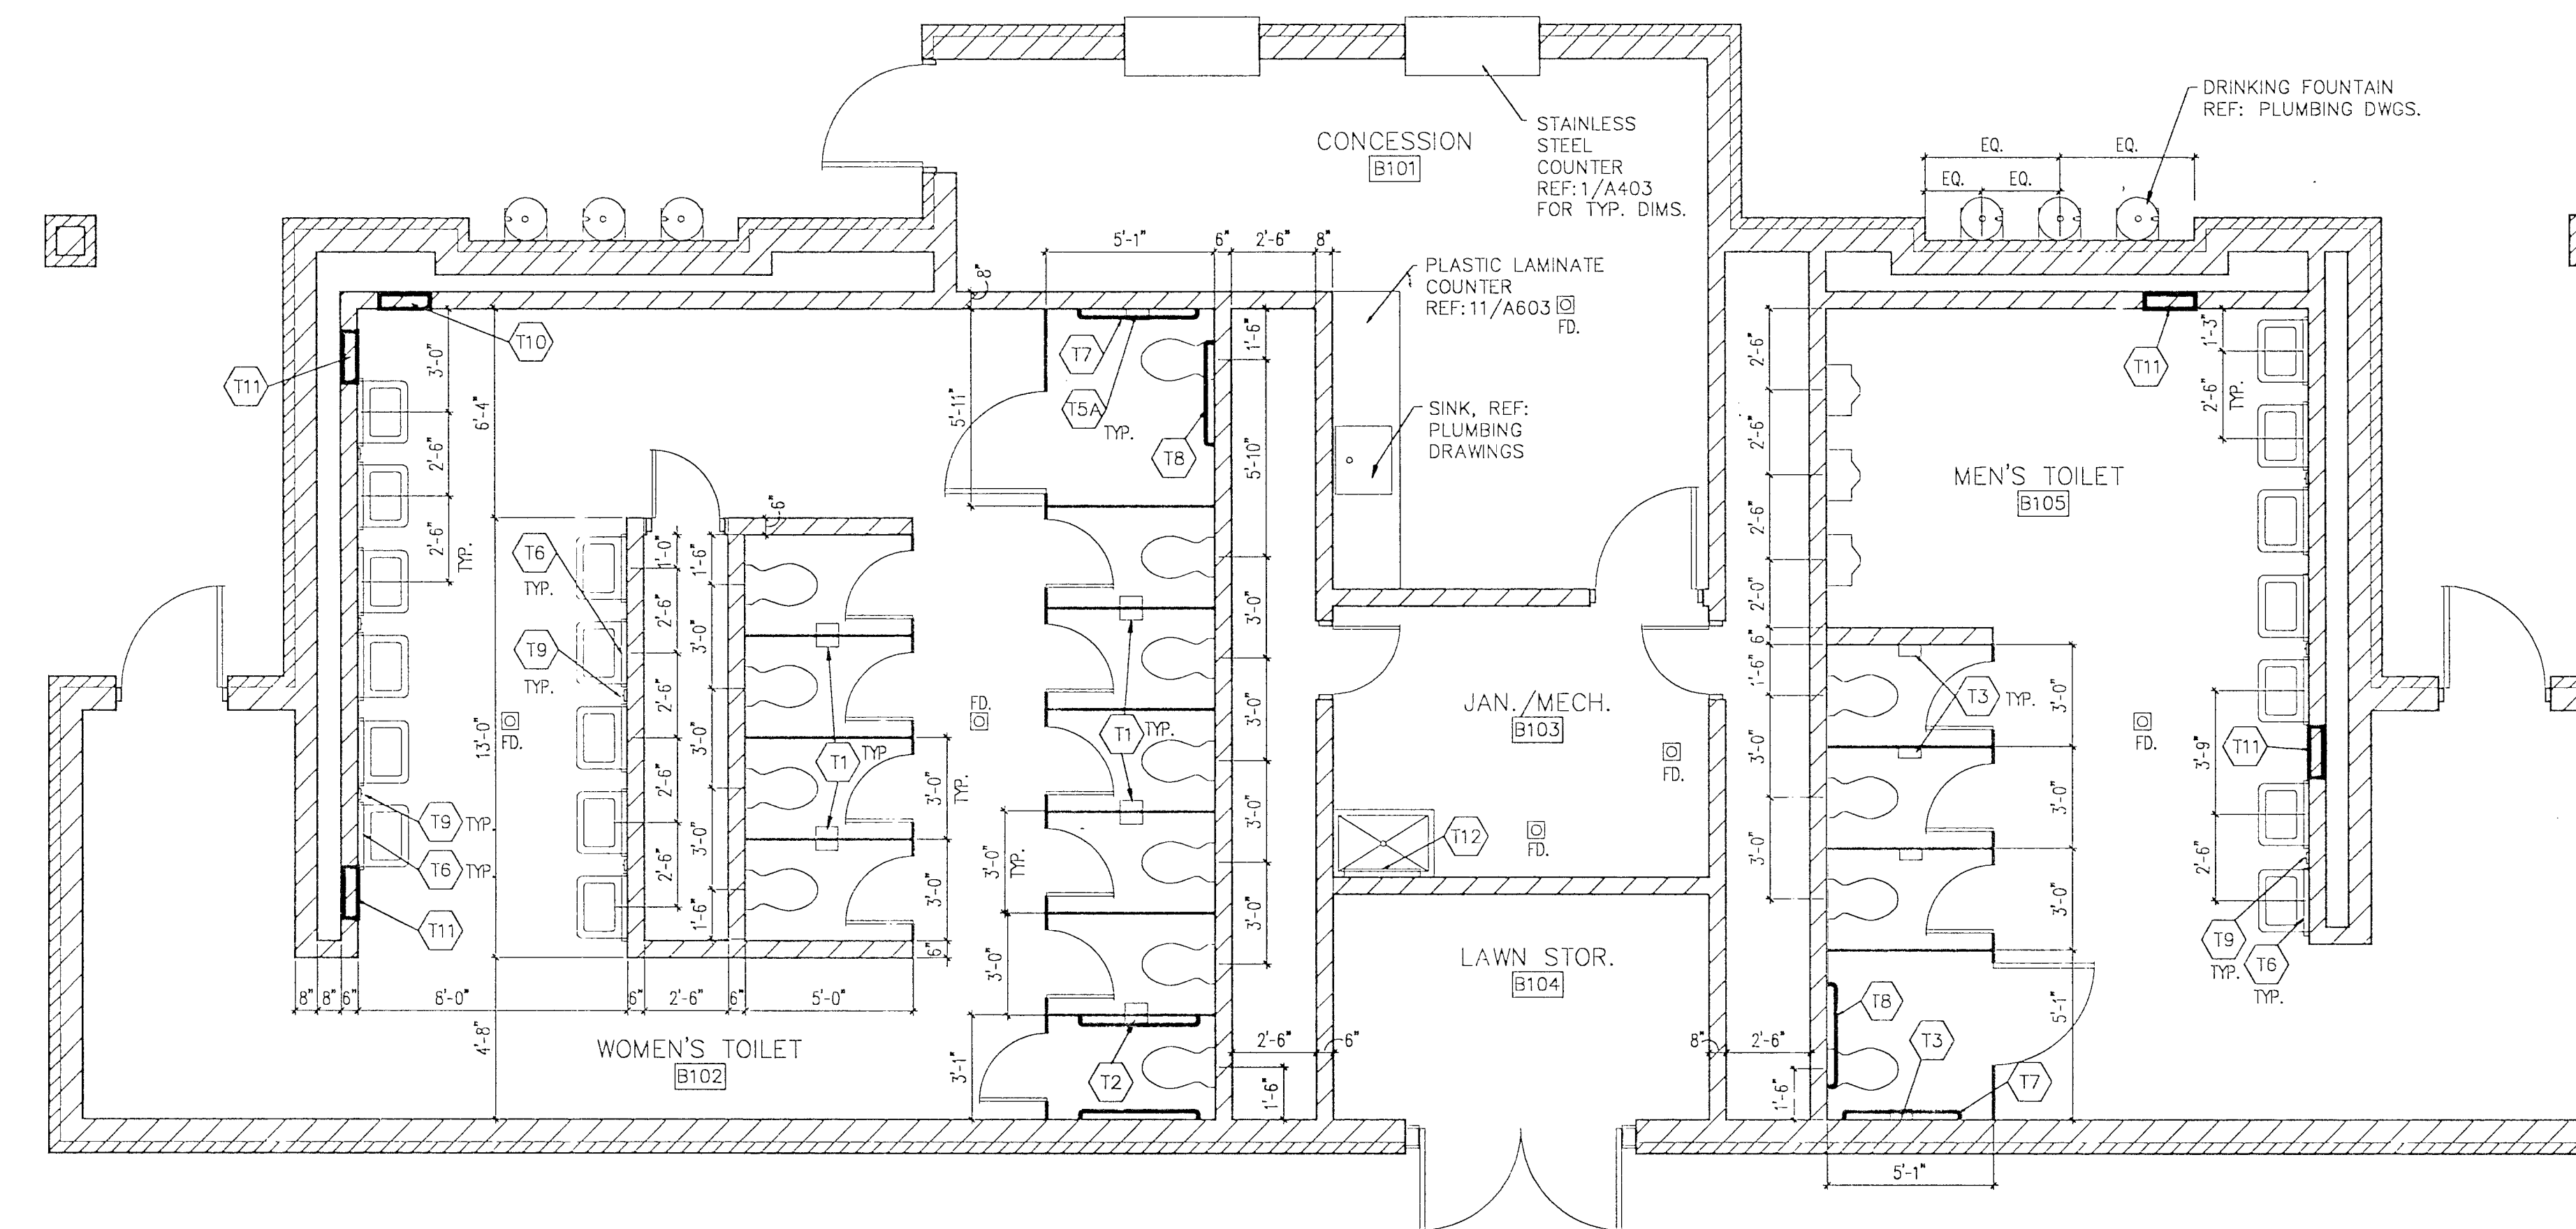

ENLARGED TOILET PLAN
VISITOR TOILET/CONCESSION


SCALE 1/4" = 1'-0"

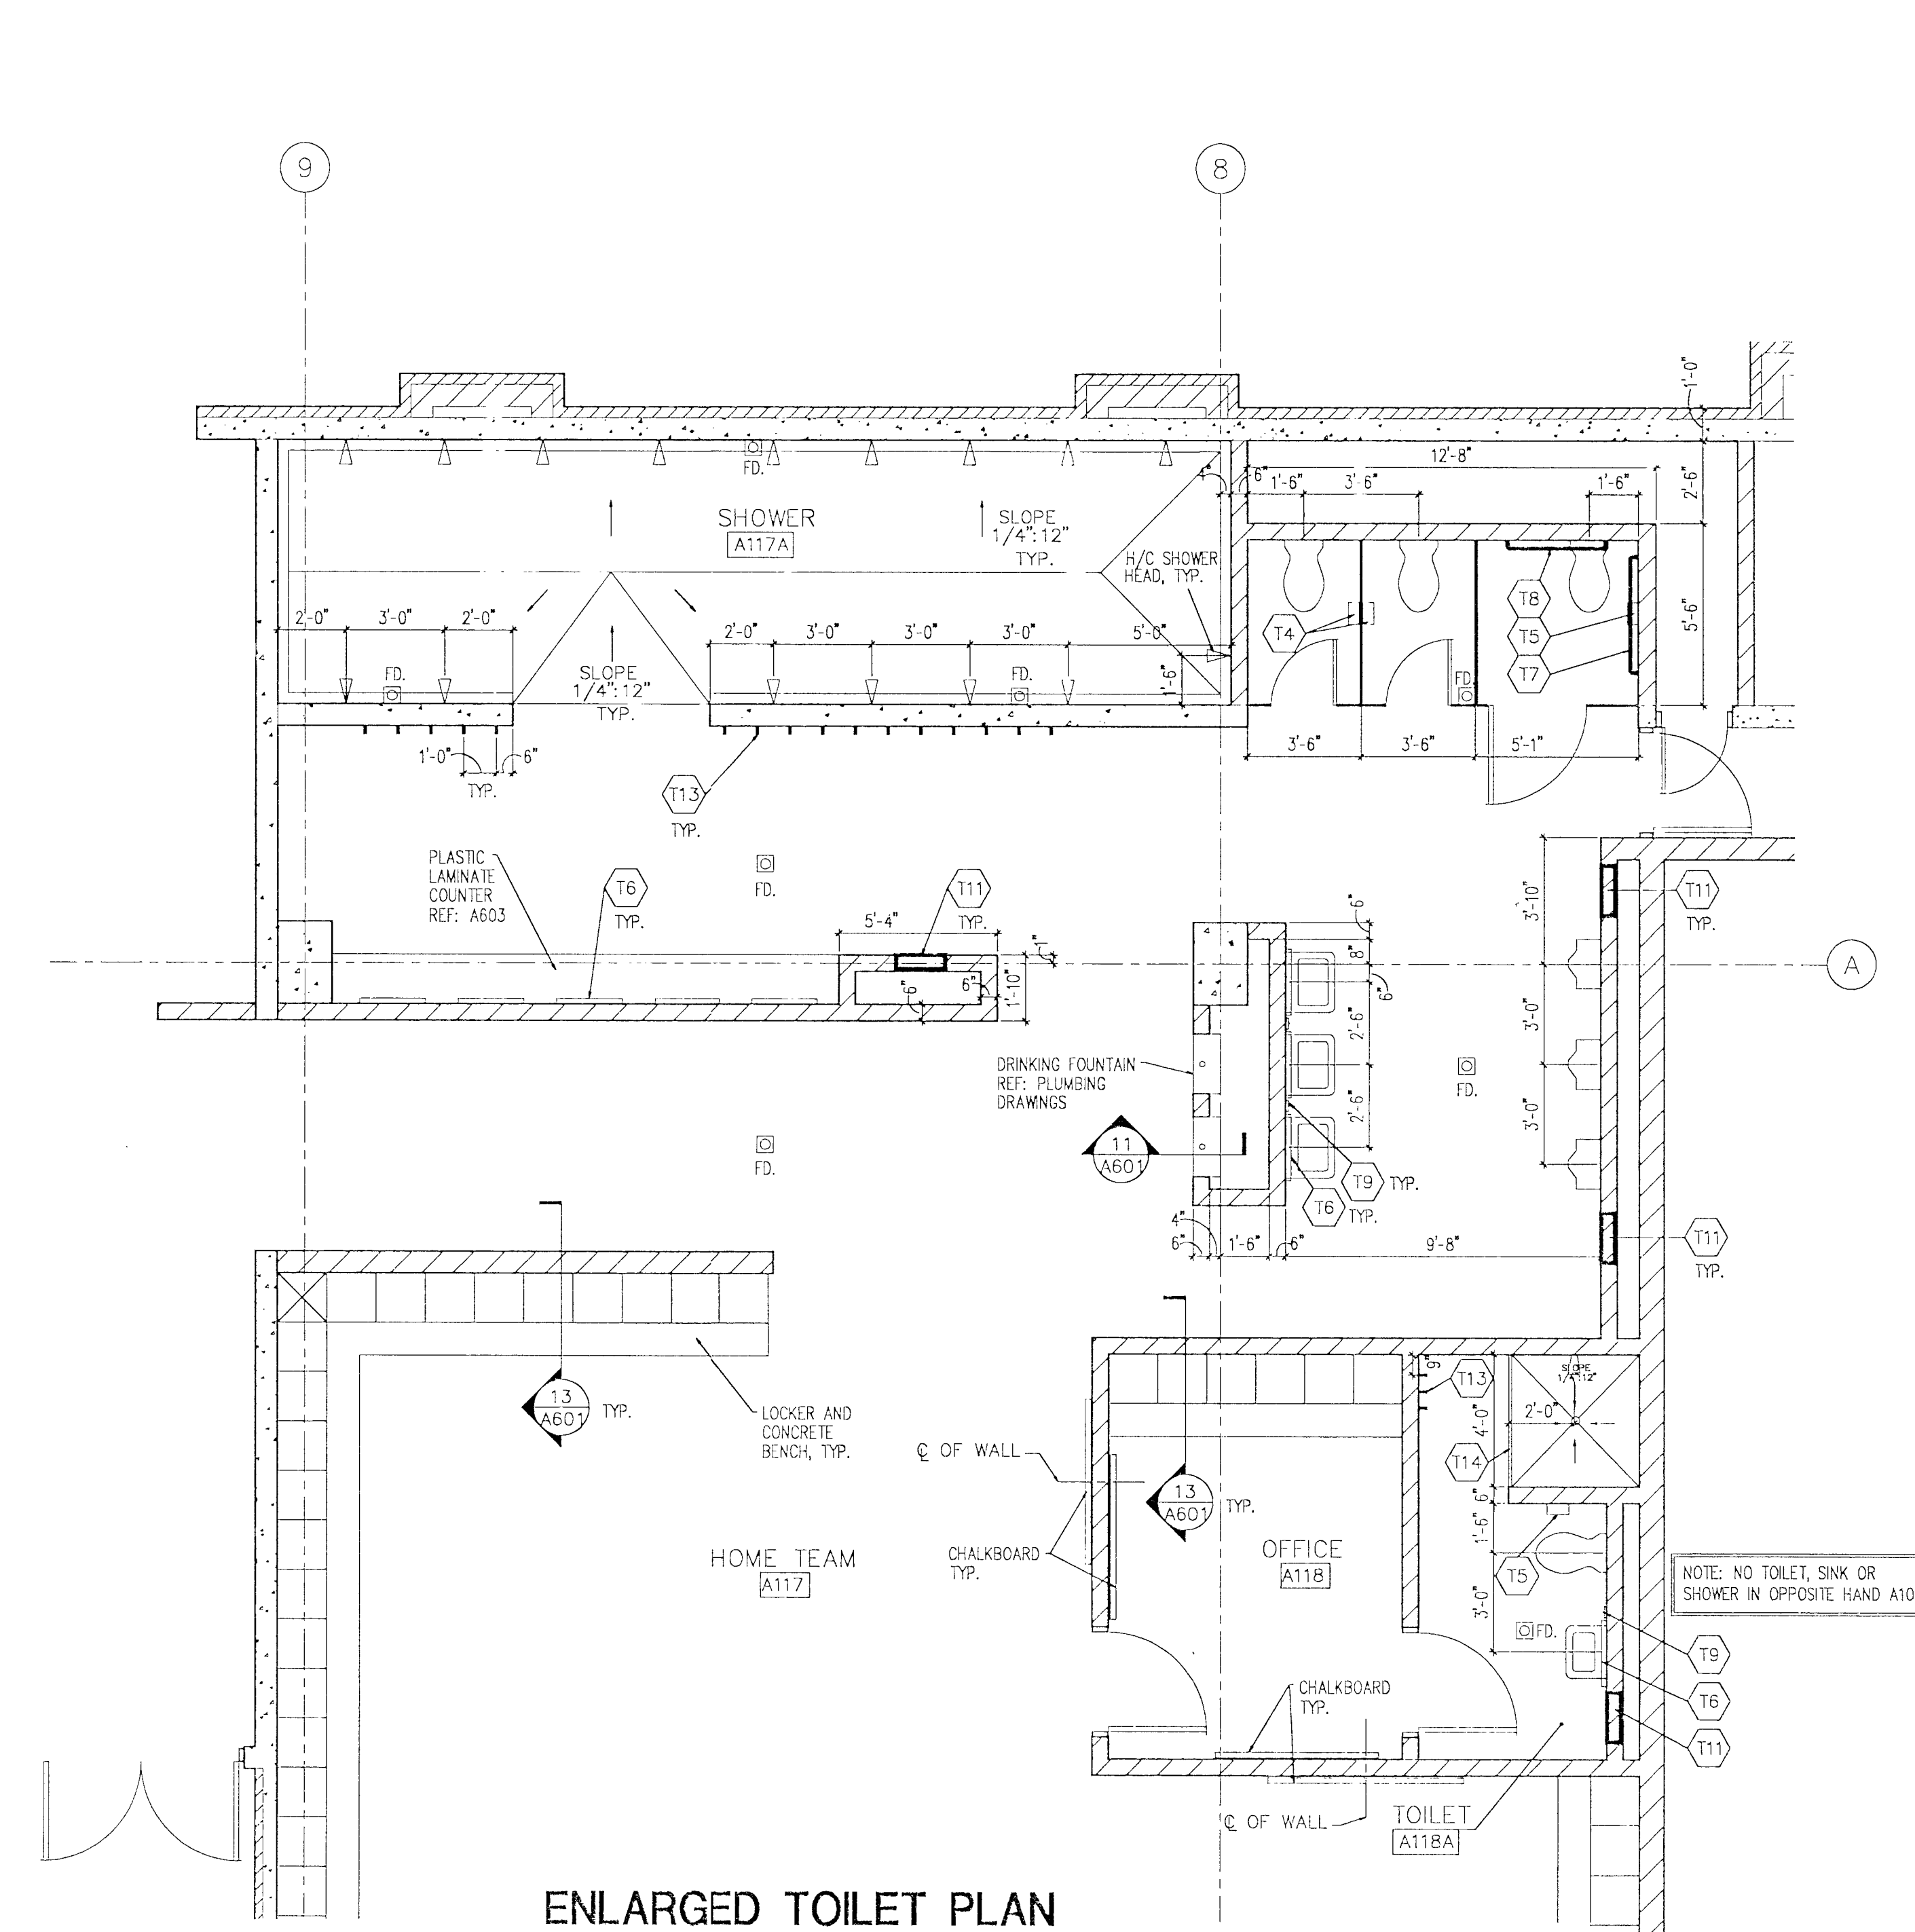

ENLARGED TOILET PLAN
FOOTBALL STADIUM LOCKER ROOM

SCALE 1/4" = 1'-0"

NOTE: OPP. HAND A104 AND A104A

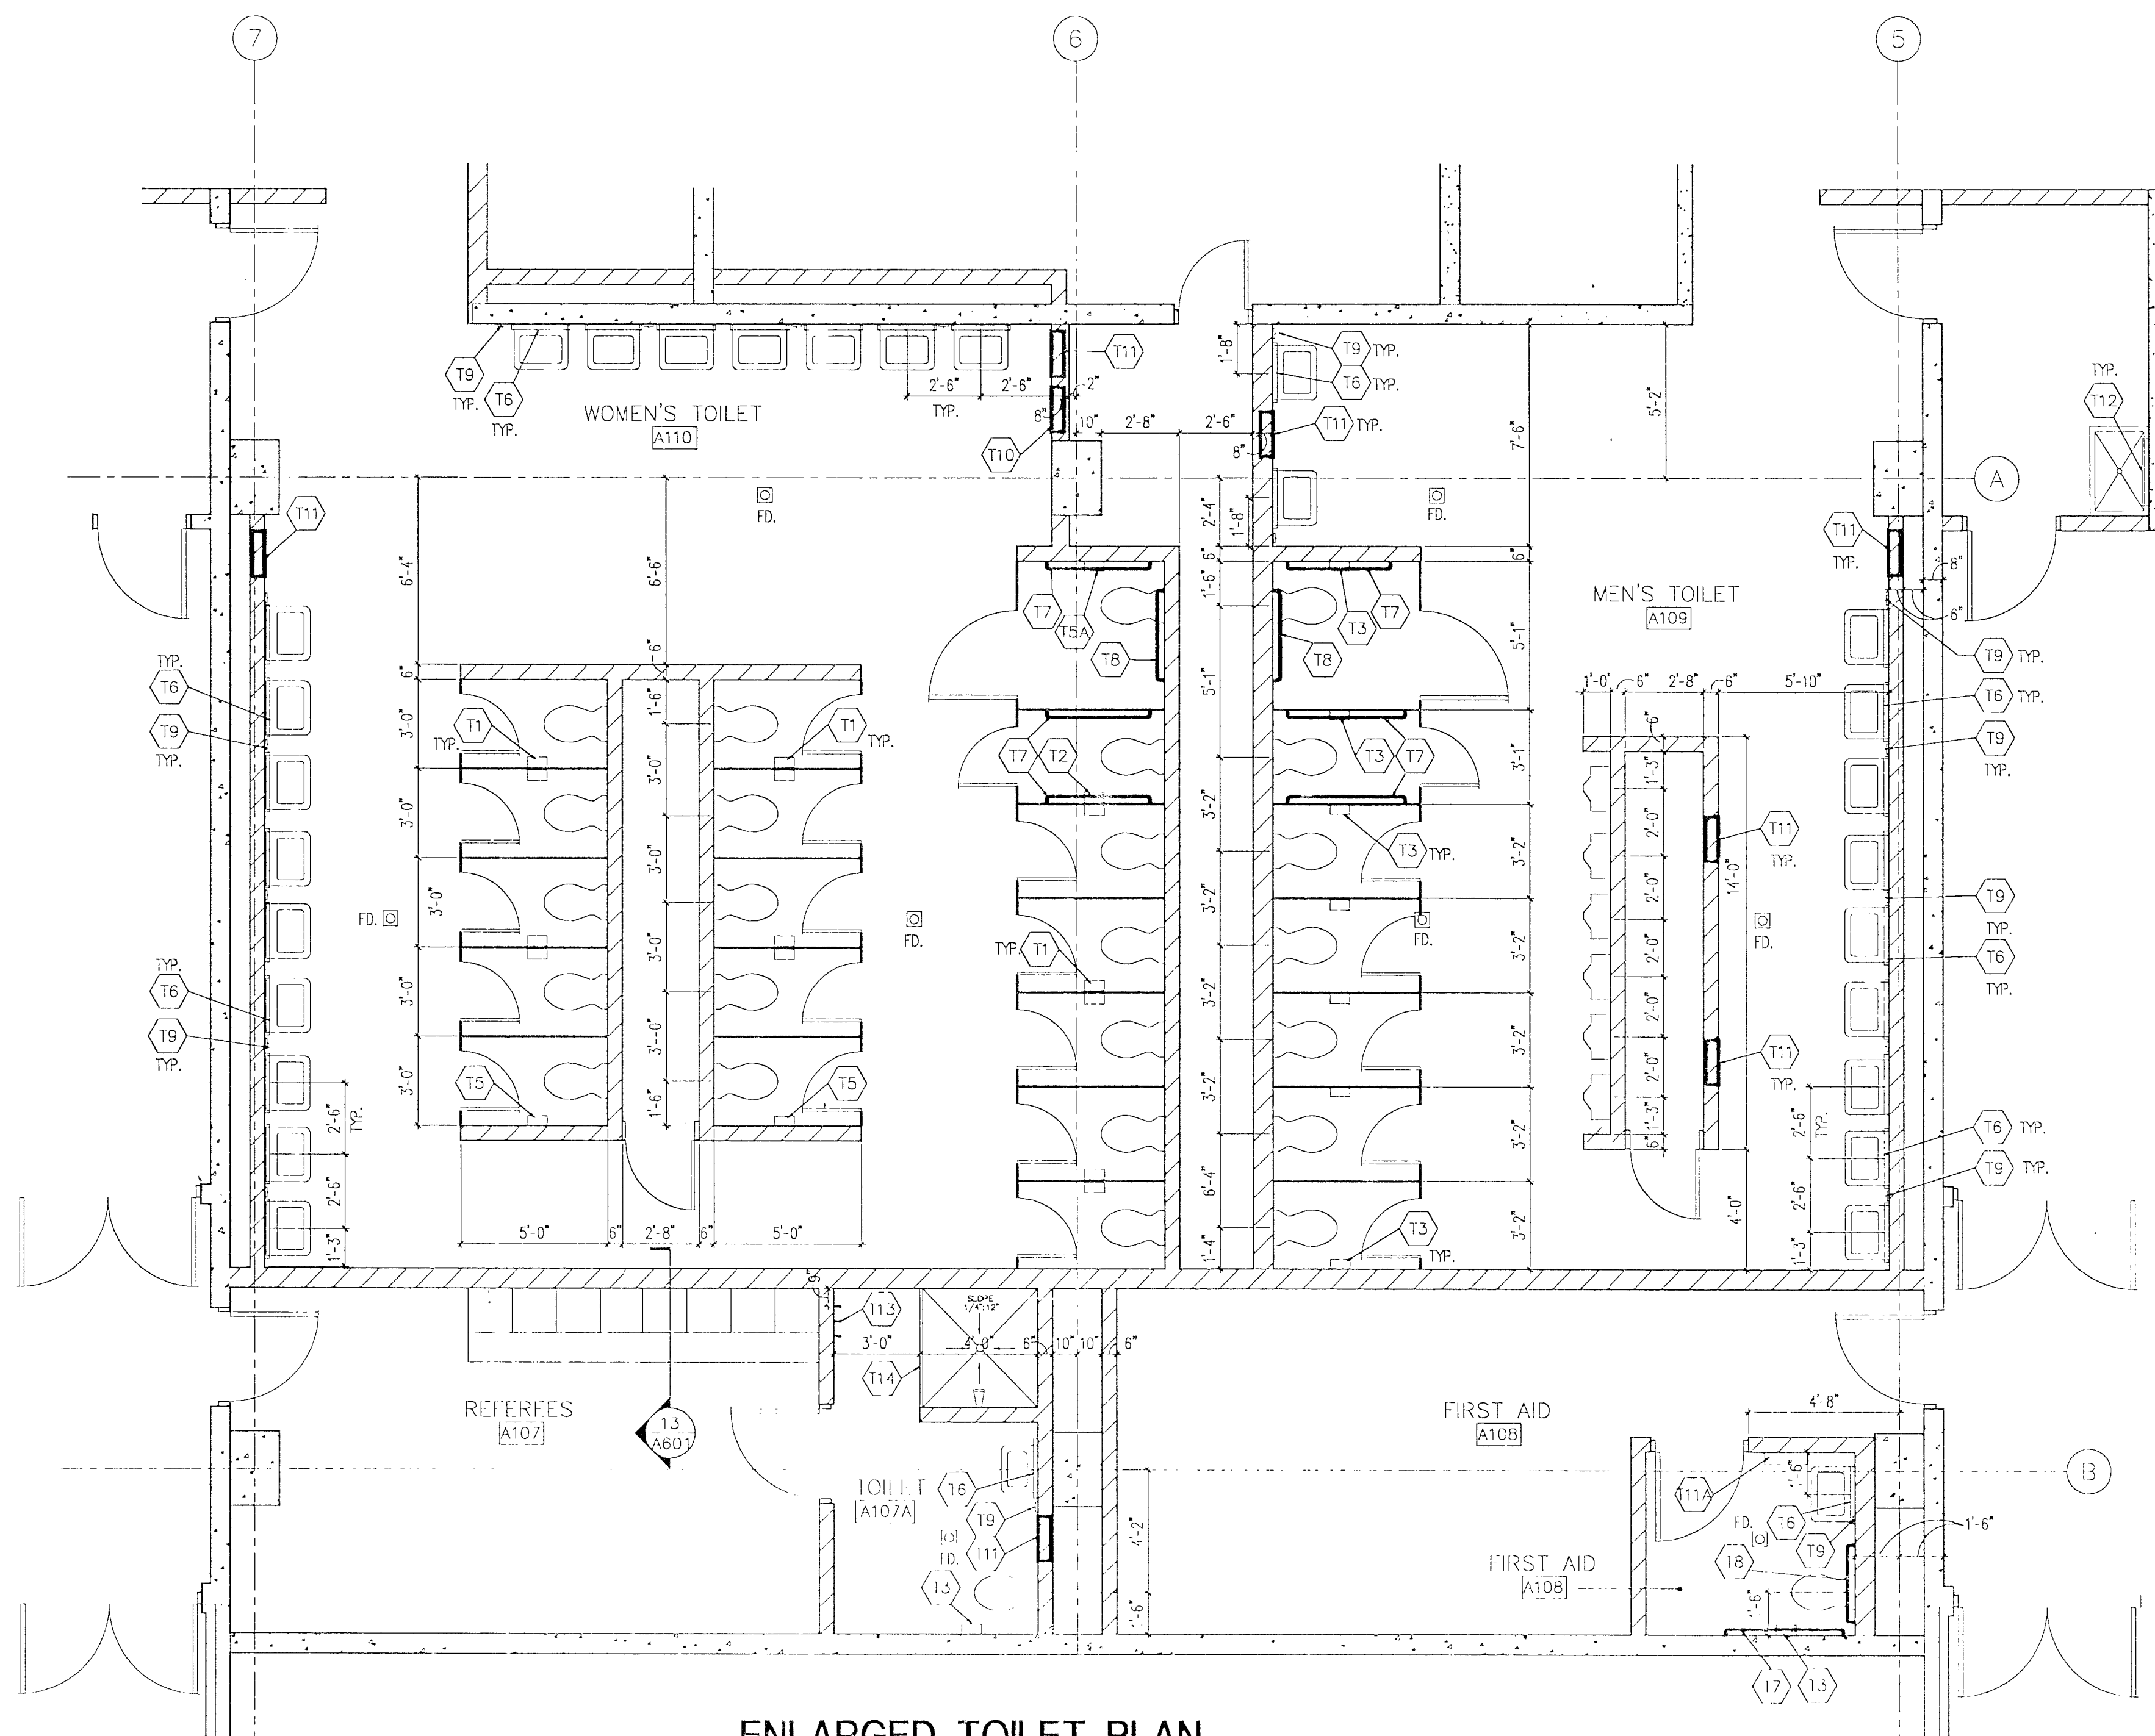

ENLARGED TOILET PLAN
FOOTBALL STADIUM PUBLIC TOILET

SCALE 1/4" = 1'-0"



THE ODLÉ MCGUIRE & SHOOK CORPORATION
ARCHITECTURE • ENGINEERING • LANDSCAPE ARCHITECTURE • INTERIOR DESIGN
6765 NORTH STATE ROAD 37, POST OFFICE BOX 2149, BLOOMINGTON, INDIANA 47402, 812/876-2020
8275 ALISON POINTE TRAIL, POST OFFICE BOX 90428, INDIANAPOLIS, INDIANA 46250, 317/842-0000

REVISIONS


© Copyright 1984 by THE ODLÉ MCGUIRE & SHOOK CORPORATION. Copyright includes architectural work, building design, plans or drawings, and specifications. Architectural work is the overall form as well as the arrangement and composition of space and elements in the design. Reproduction without written permission is prohibited.

MICHIGAN CITY SPORTS COMPLEX
AMES FIELD
MICHIGAN CITY, INDIANA

PROJECT NO. 93052
DATE MAY 31, 1984
drawn by: MFM, PAM
checked by: GKJ

A204


ENLARGED TOILET
PLANS

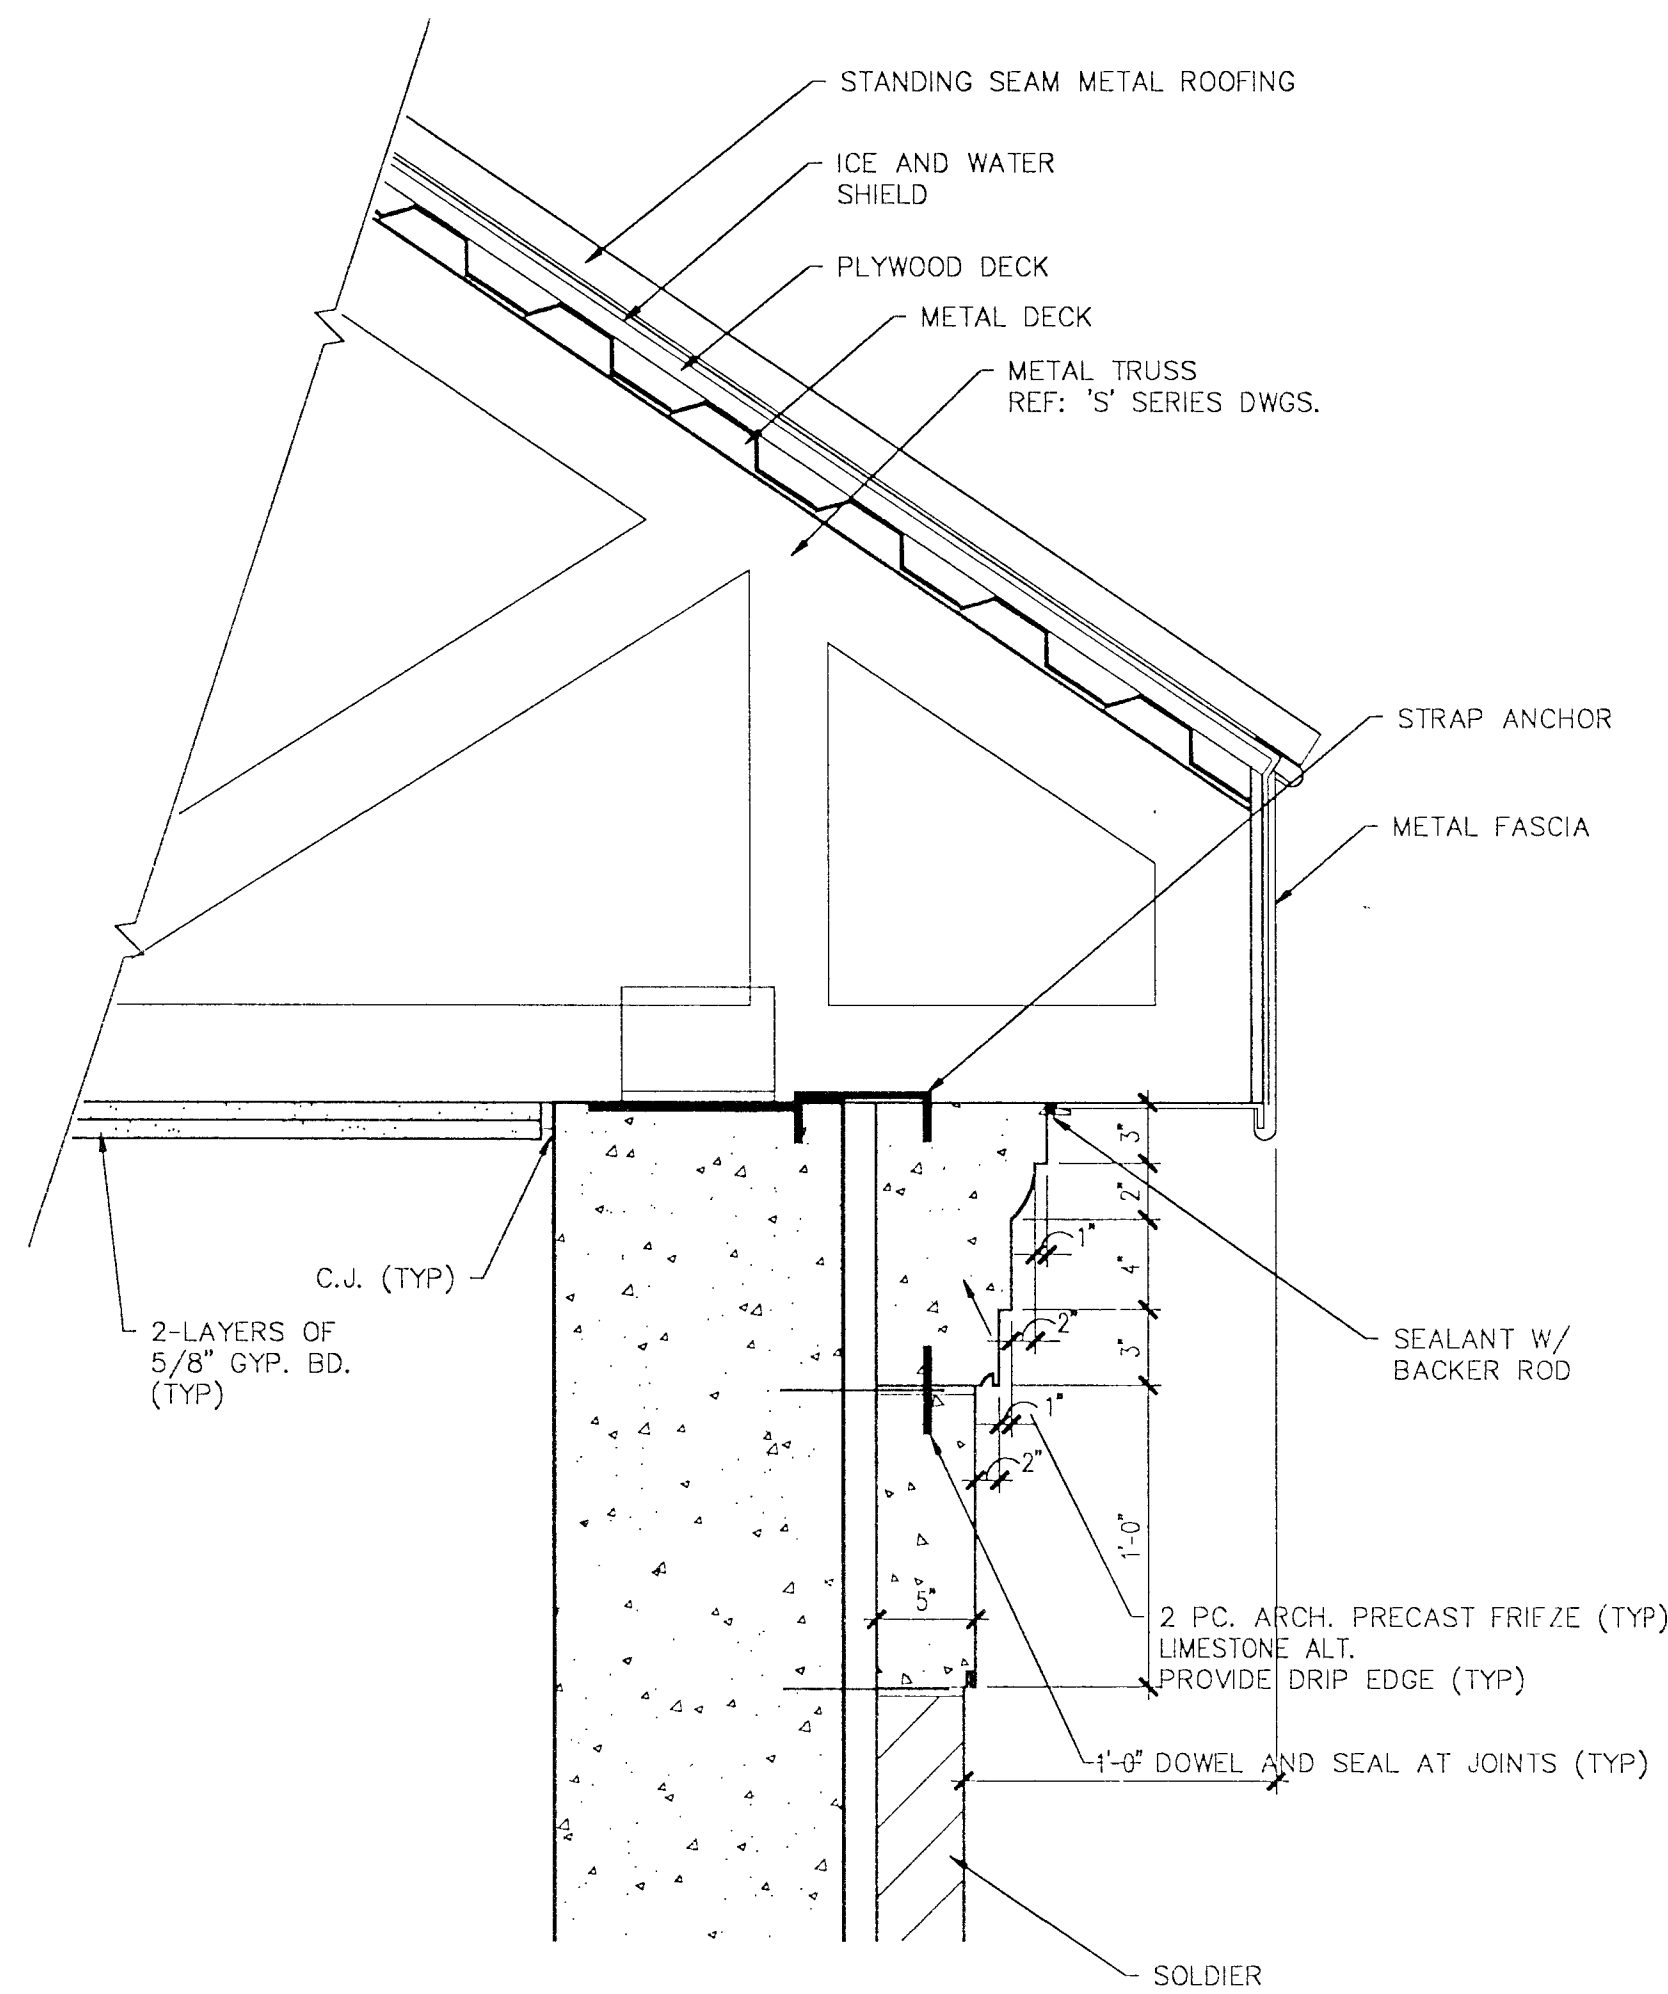

SOFFIT DETAIL

SCALE 1 1/2" = 1'-0"


7
A205

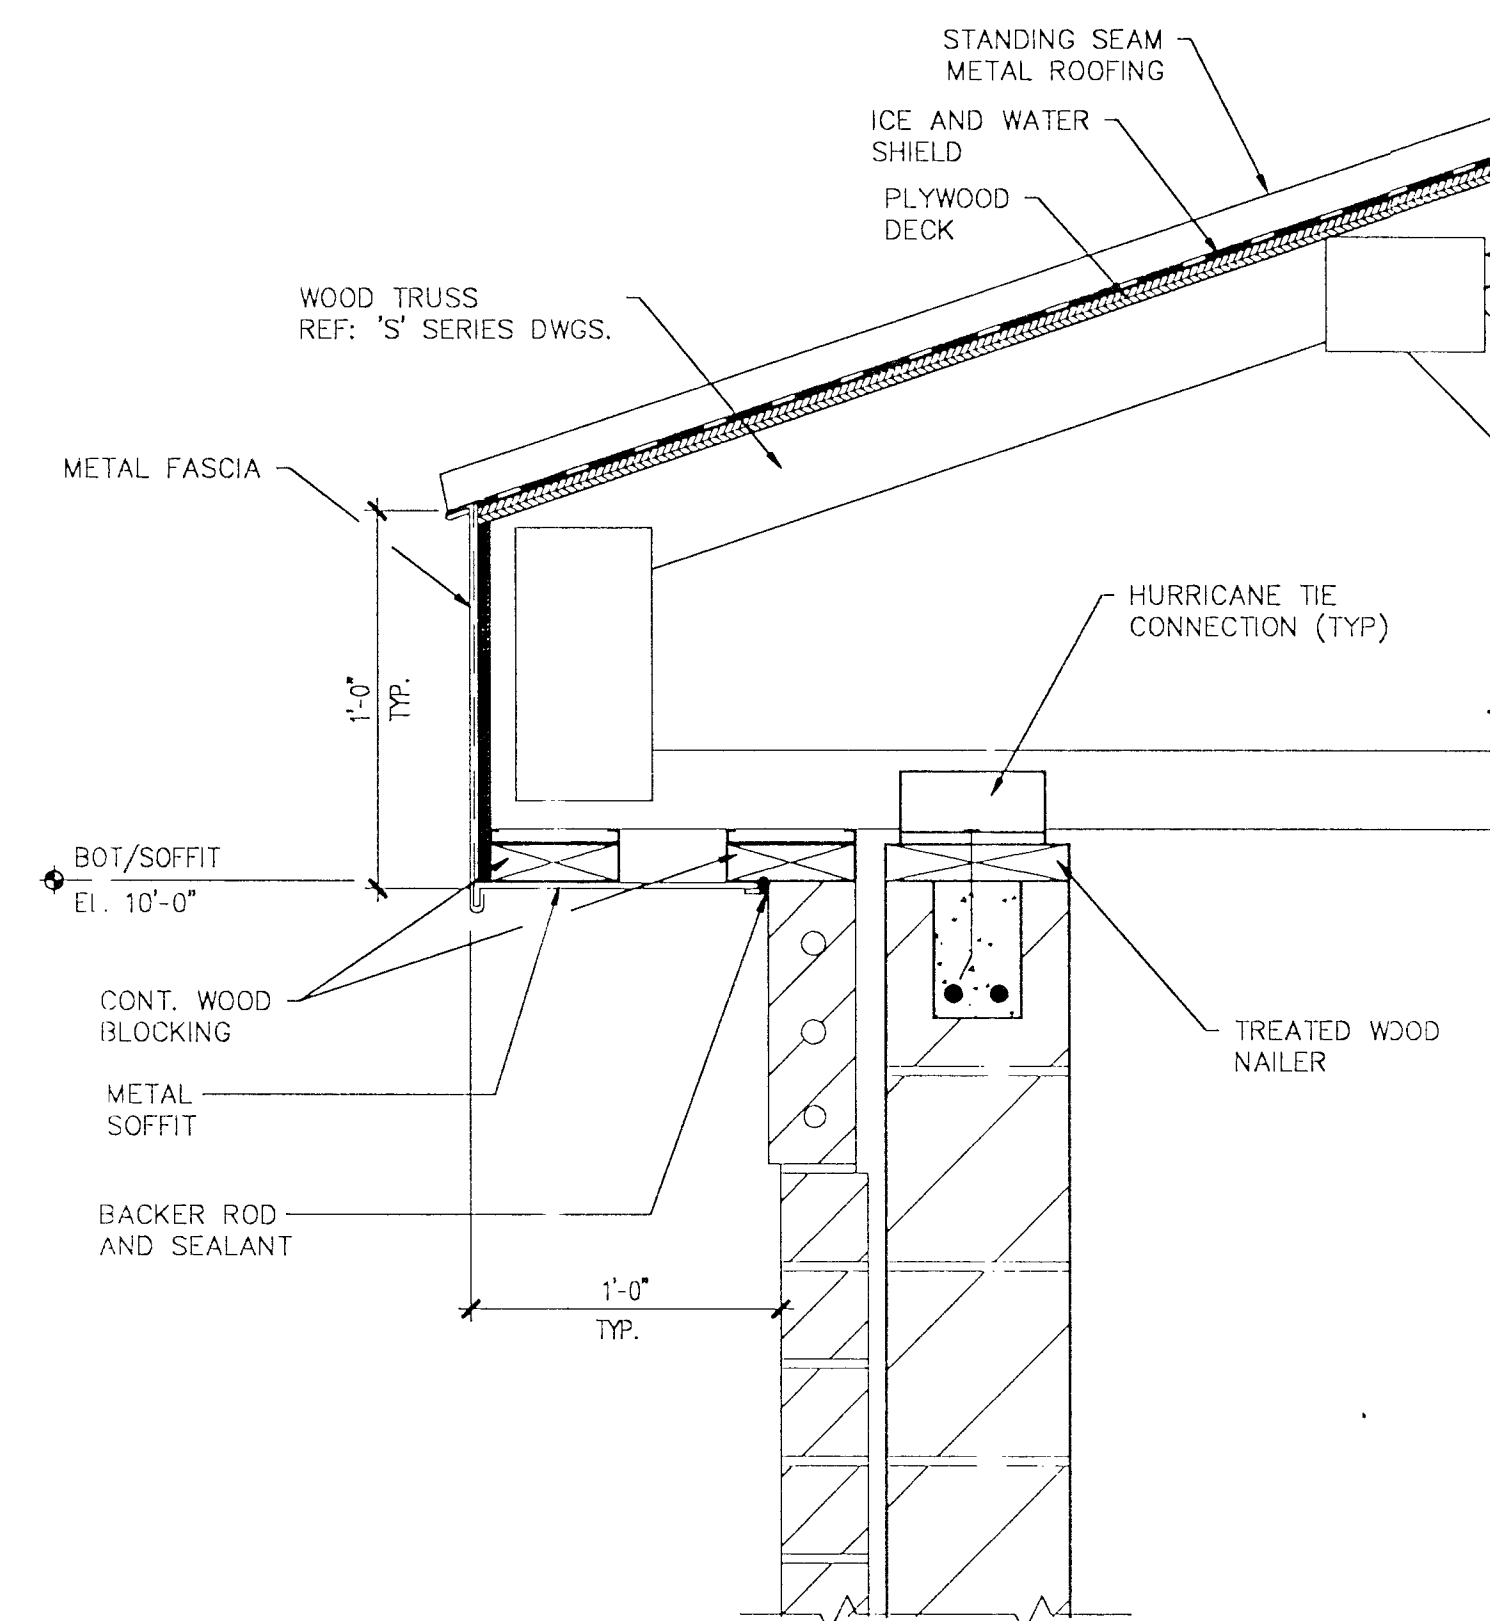

TYPICAL SOFFIT DETAIL

SCALE 1 1/2" = 1'-0"


4
A205

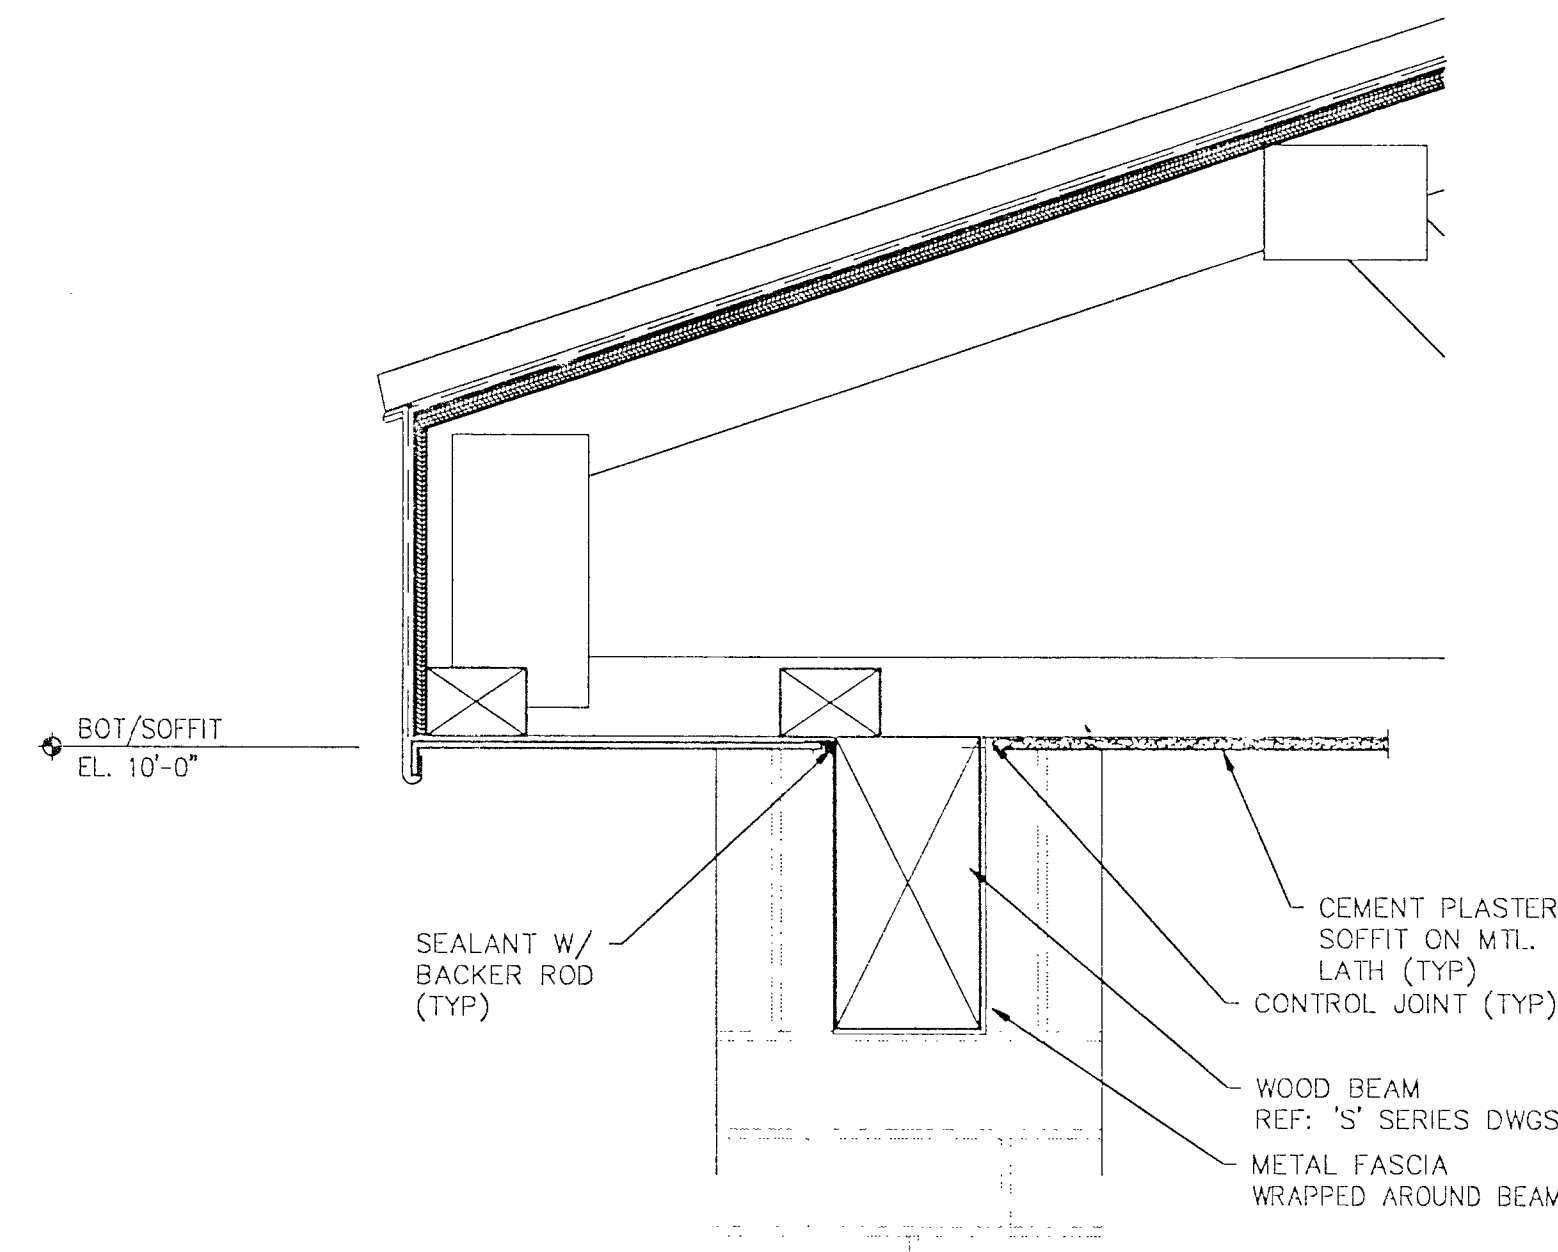

SOFFIT DETAIL

SCALE 1 1/2" = 1'-0"


6
A205

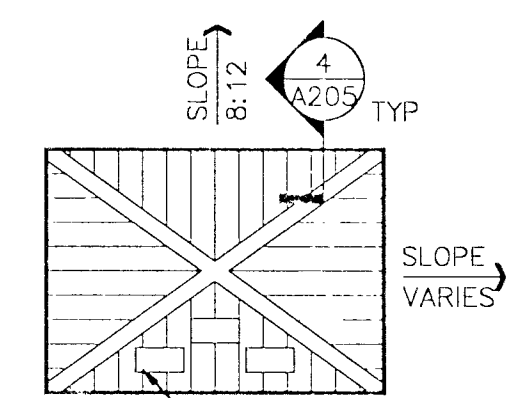

TYPICAL TICKET BOOTH ROOF PLAN

SCALE 1/8" = 1'-0"


3
A205

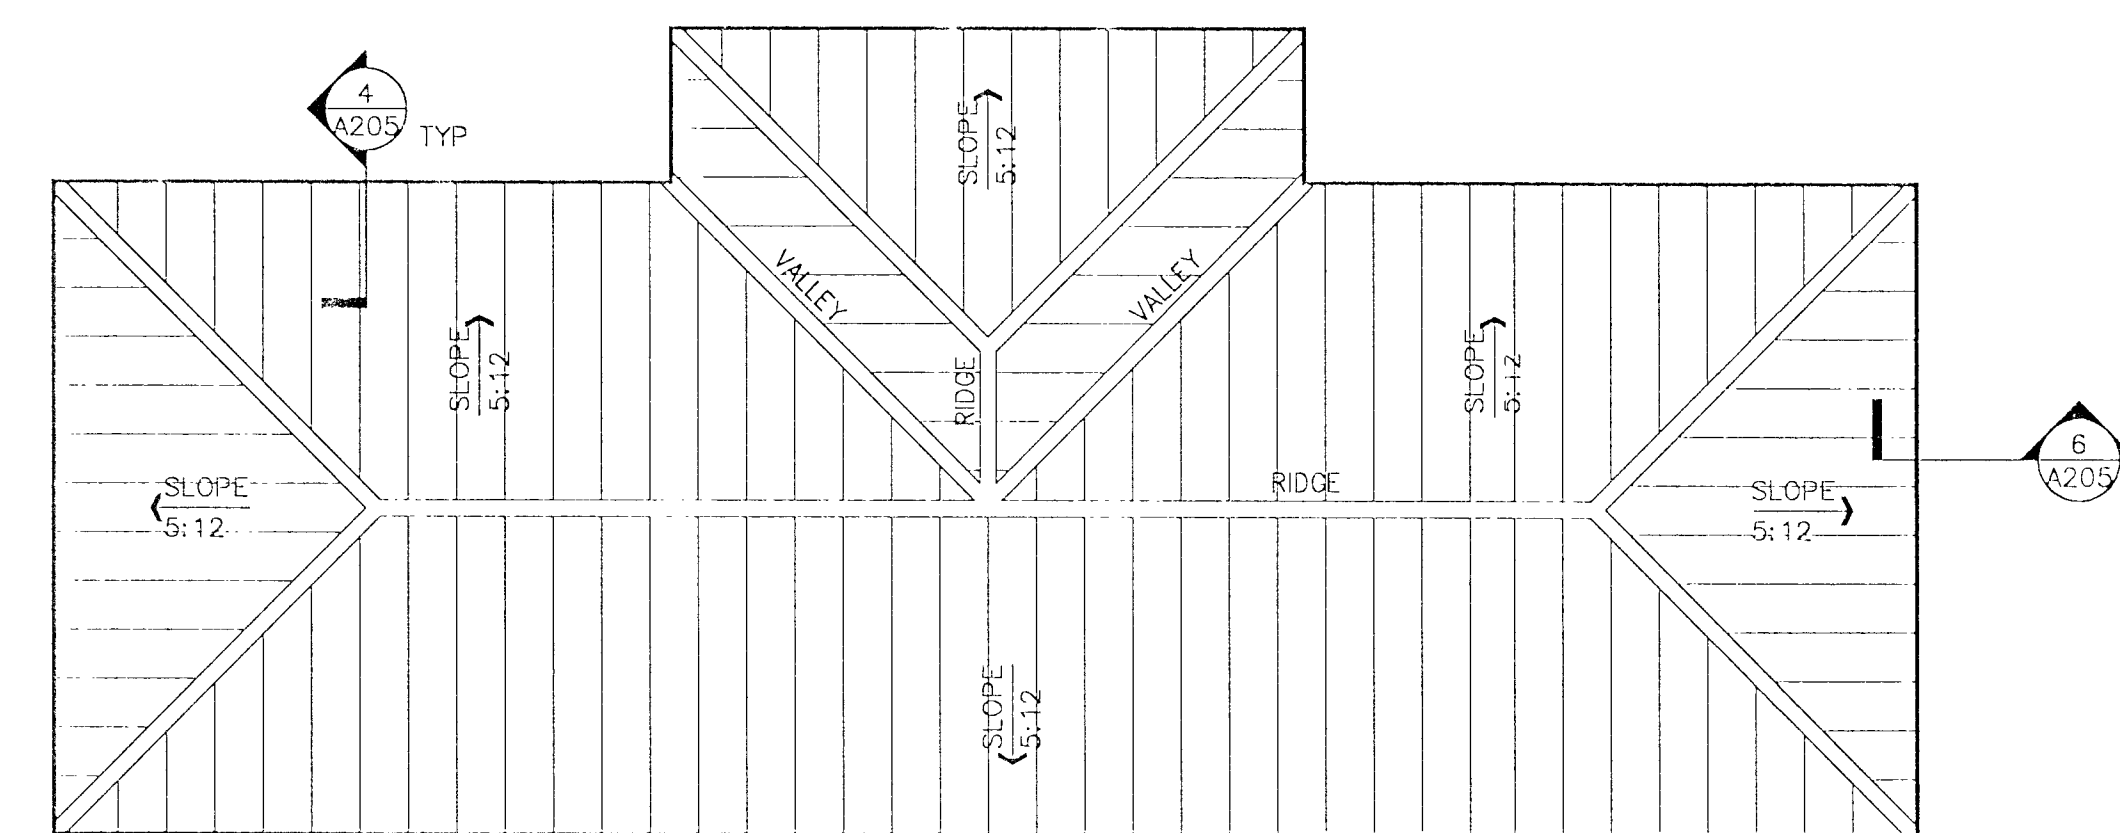

VISITOR TOILET/CONCESSION ROOF PLAN

SCALE 1/8" = 1'-0"


2
A205

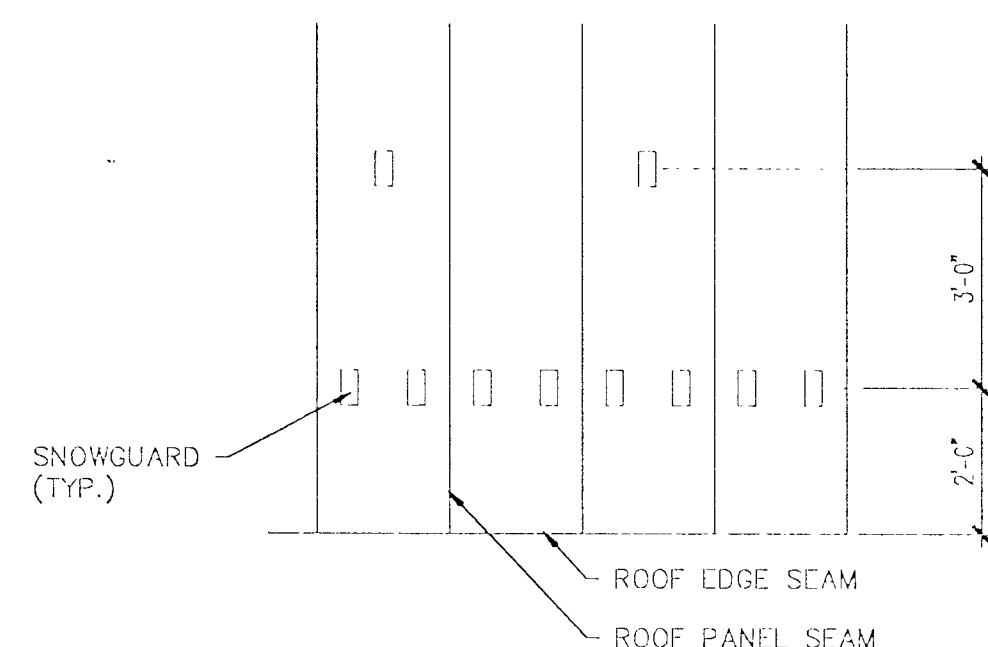

SNOW GUARD DETAIL

SCALE 3/4" = 1'-0"

5
A205

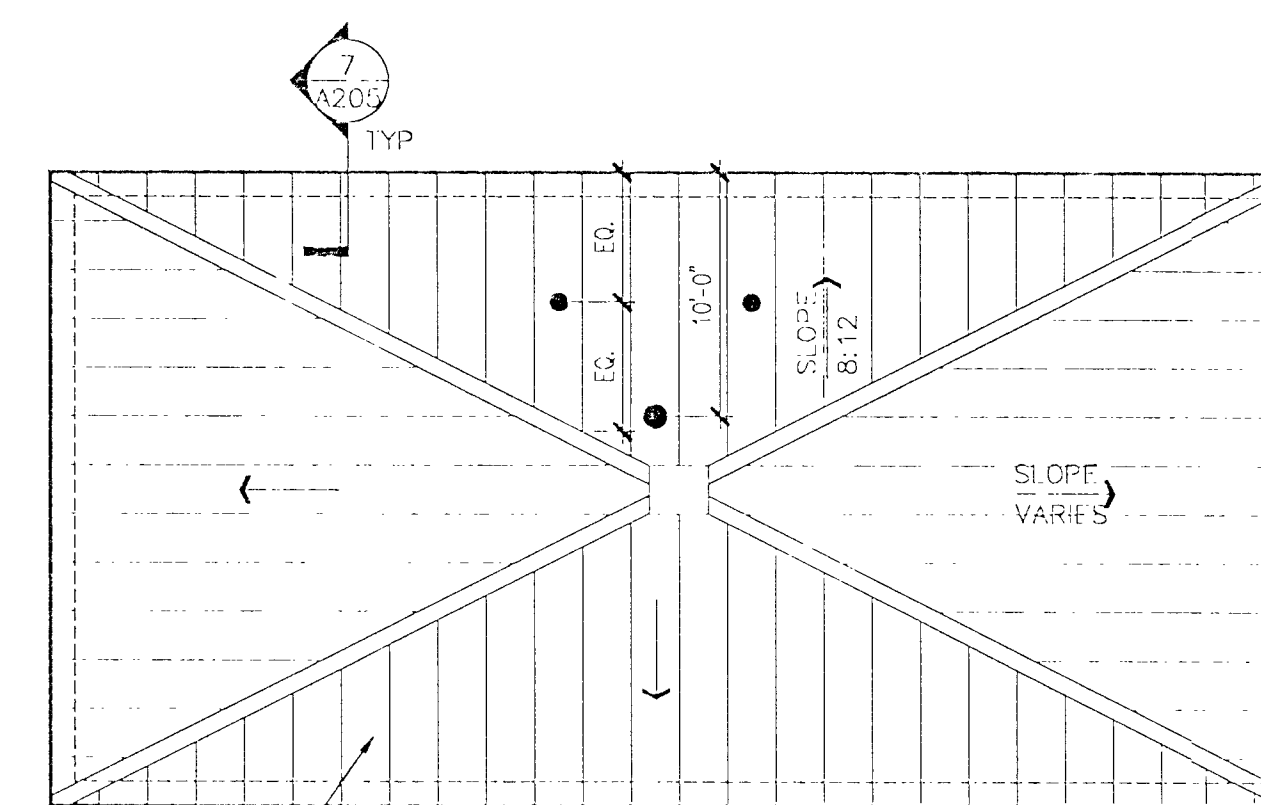


FOOTBALL STADIUM ROOF PLAN

SCALE 1/8" = 1'-0"

1
A205

NOTE: ALL ROOF MATERIALS TO BE STANDING SEAM METAL ROOF W/ ALUMINUM FASCIA & SOFFITS.

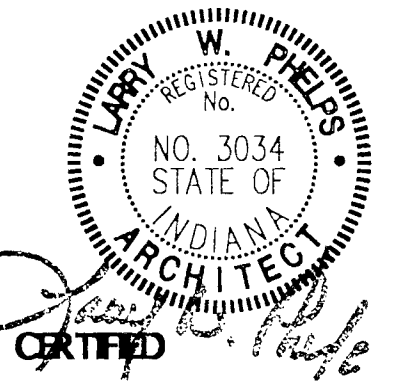

THE ODLE MCGUIRE & SHOOK CORPORATION
ARCHITECTURE • ENGINEERING • LANDSCAPE ARCHITECTURE • INTERIOR DESIGN
6765 NORTH STATE ROAD 37, POST OFFICE BOX 2149, BLOOMINGTON, INDIANA 47402, 817/876-2000
8275 ALLISON POINTE TRAIL, POST OFFICE BOX 3426, INDIANAPOLIS, INDIANA 46250, 317/842-0060


REVISIONS

© Copyright 1994 by THE ODLE MCGUIRE & SHOOK CORPORATION. Copyright includes architectural work, building design, plans or drawings, and specifications. Architectural work is the mental form as well as the arrangement and composition of space and elements in the design. Reproduction without written permission is prohibited.

MICHIGAN CITY SPORTS COMPLEX
AMES FIELD
MICHIGAN CITY, INDIANA


PROJECT NO. 93052
DATE MAY 31, 1994
drawn by JRM/JKG/MCW
checked by: GKJ

A205
ROOF PLANS & ROOF DETAILS

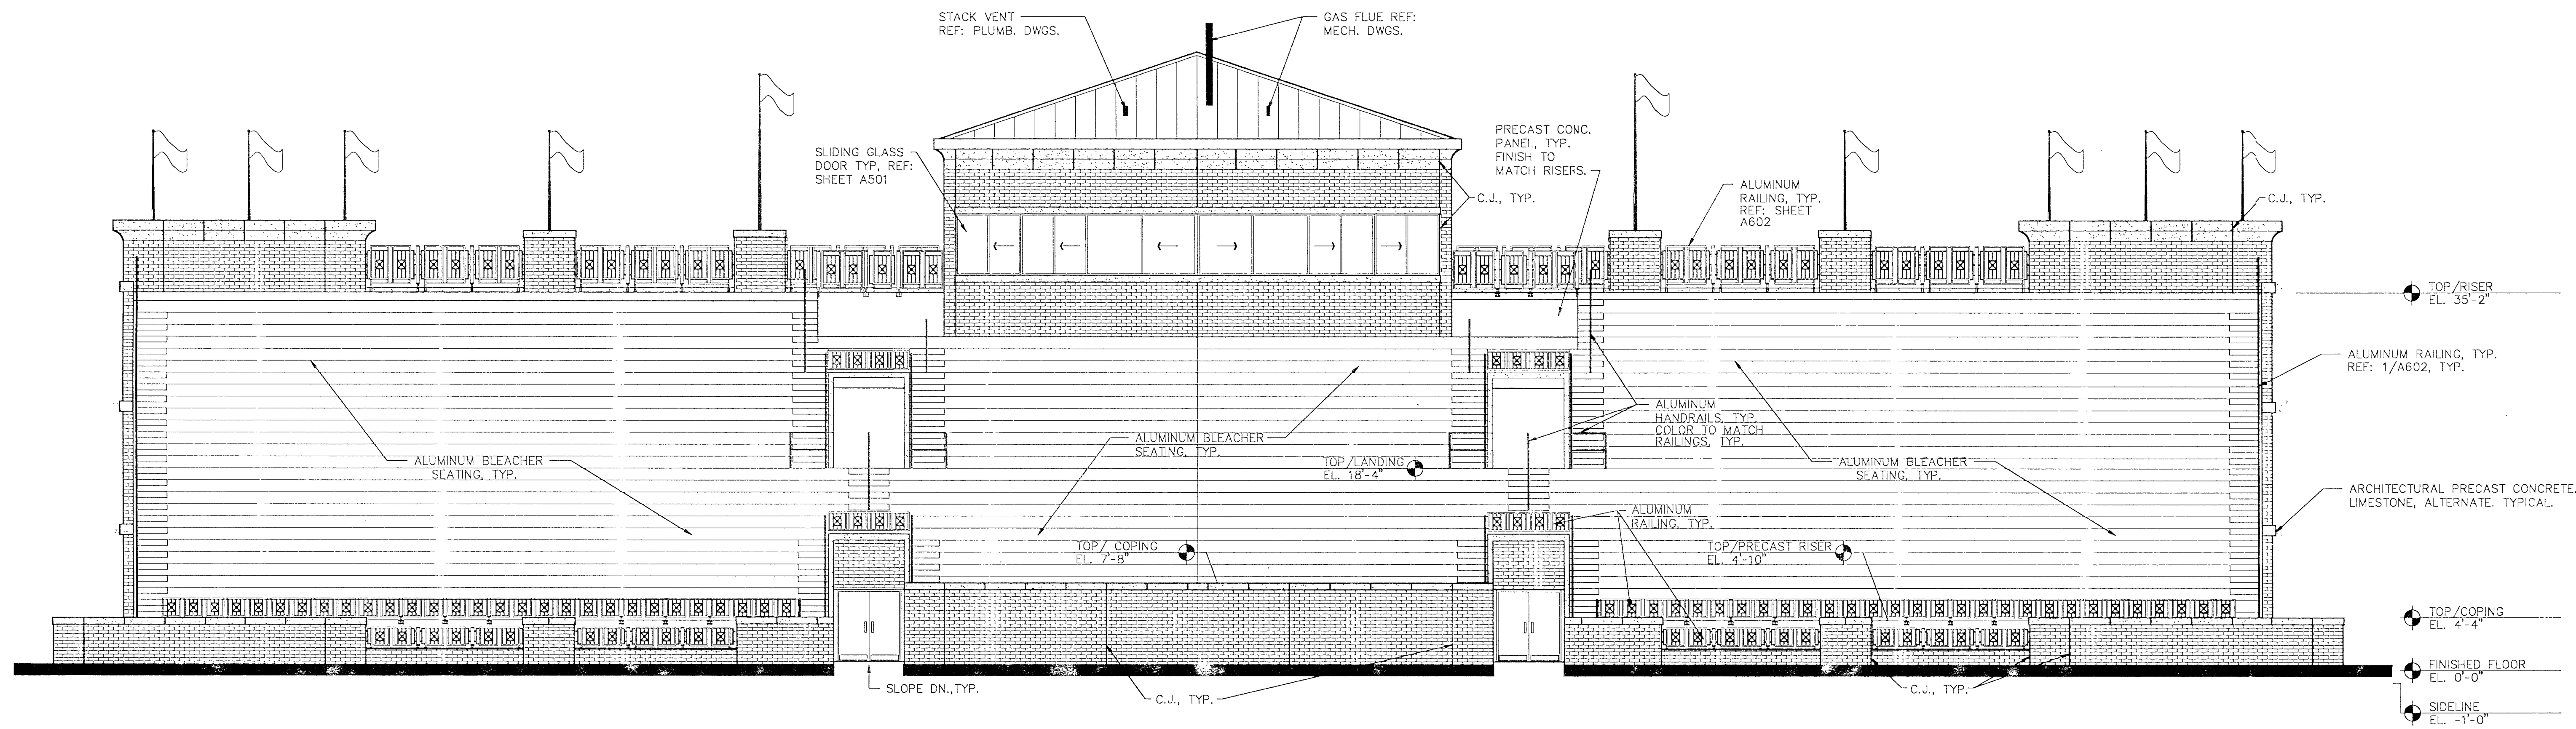

FOOTBALL GRANDSTAND NORTH ELEVATION


SCALE 1/8"=1'-0"

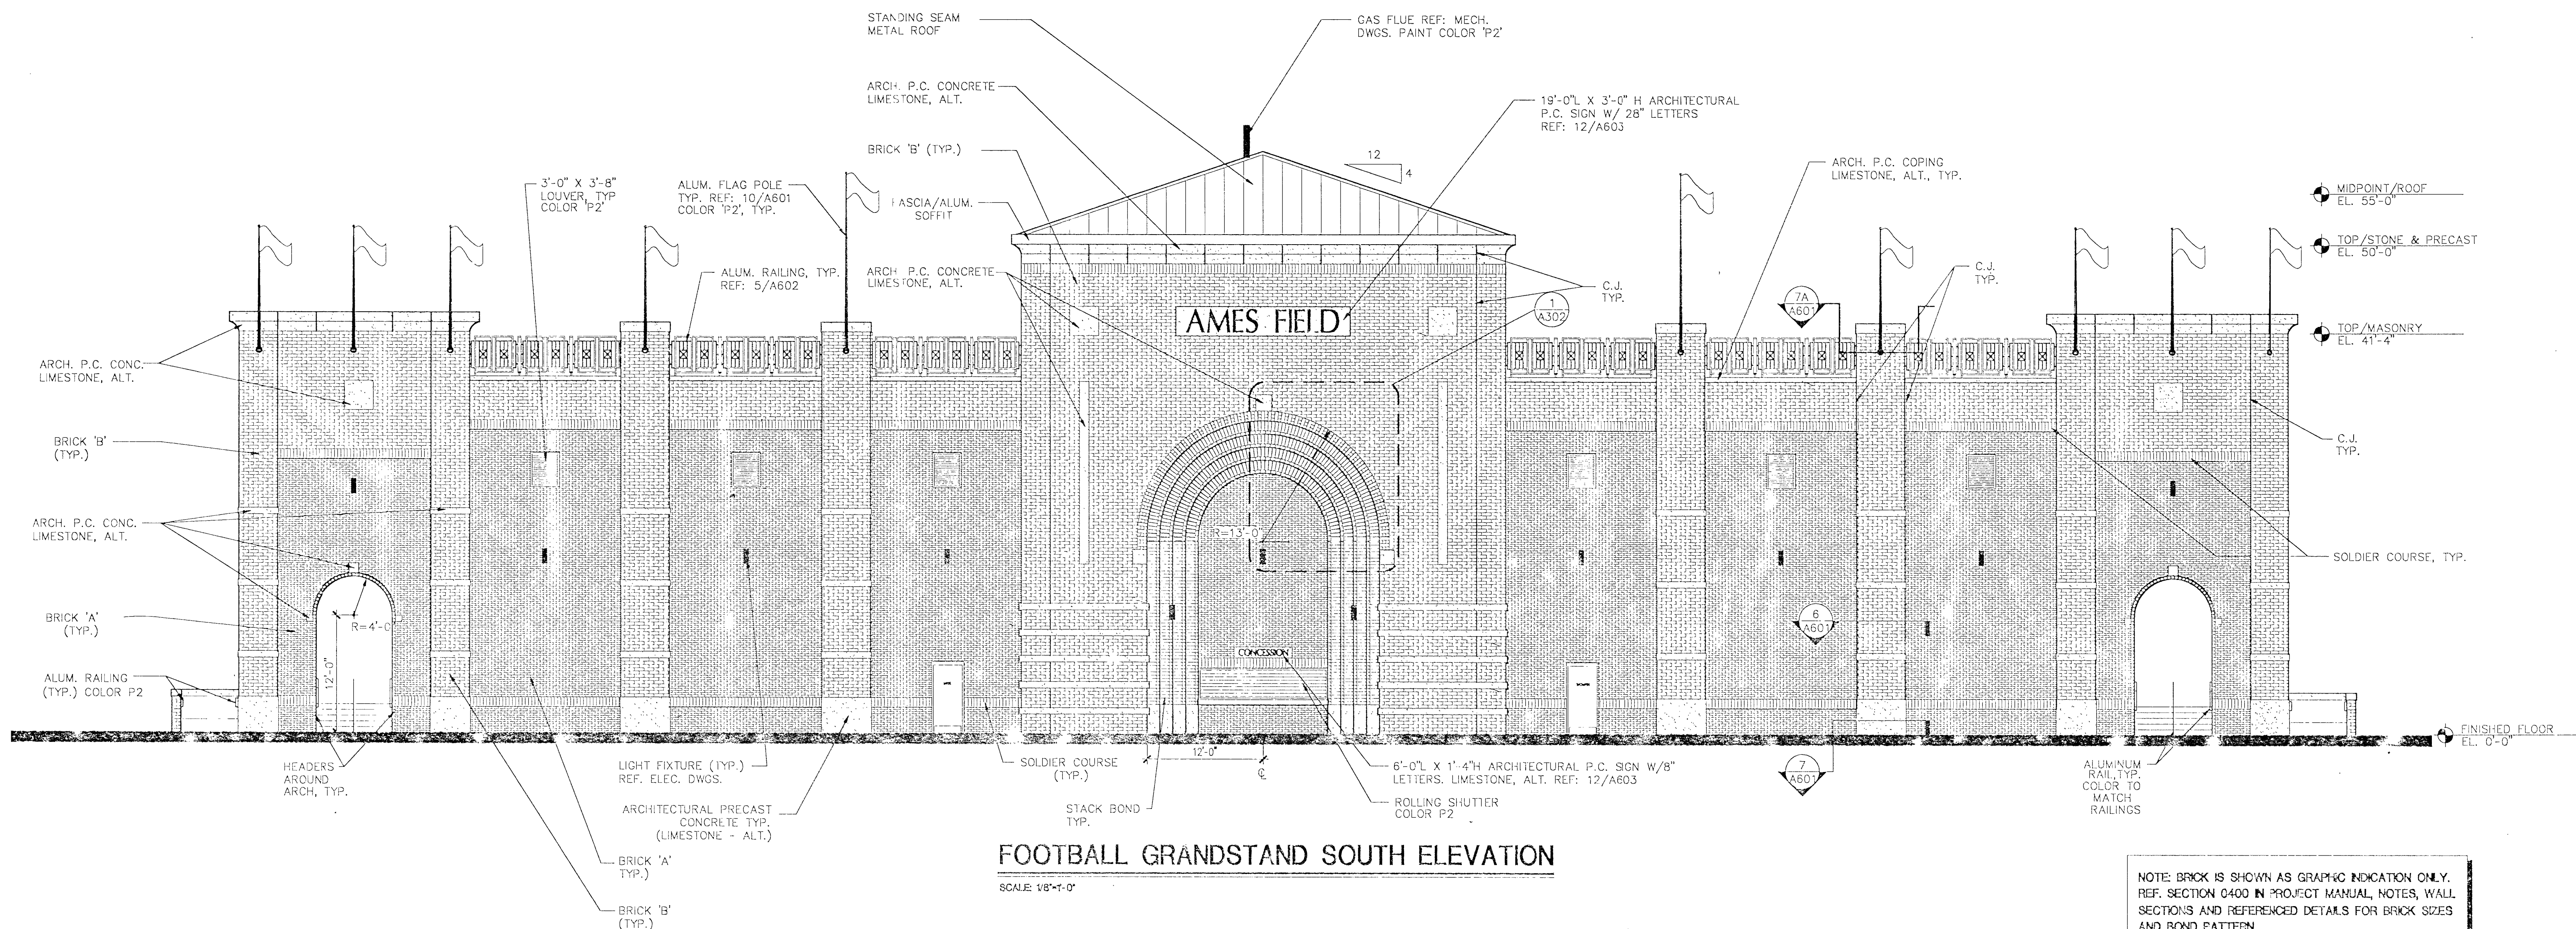

FOOTBALL GRANDSTAND SOUTH ELEVATION

SCALE 1/8"=1'-0"

NOTE: BRICK IS SHOWN AS GRAPHIC INDICATION ONLY.
REF. SECTION 0400 IN PROJECT MANUAL, NOTES, WALL
SECTIONS AND REFERENCED DETAILS FOR BRICK SIZES
AND BOND PATTERN.

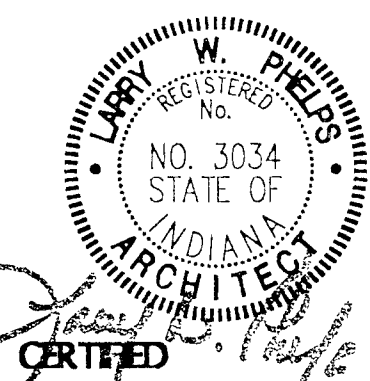

THE ODLE MCQUIRE & SHOOK CORPORATION
ARCHITECTURE • ENGINEERING • LANDSCAPE ARCHITECTURE • INTERIOR DESIGN
6755 NORTH STATE ROAD 371, POST OFFICE BOX 2149, BLOOMINGTON, INDIANA 47403, 812/875-2020
8275 ALISON POINTE TRAIL, POST OFFICE BOX 50428, INDIANAPOLIS, INDIANA 46250, 317/842-5000

REVISIONS

© Copyright 1984 by THE ODLE MCQUIRE & SHOOK CORPORATION. Copyright includes architectural work, building design, plans or drawings, and specifications. Architectural work is the result of the design and artistic skill of the architect and is the property of the architect. No part of this design may be reproduced without written permission of the architect.

MICHIGAN CITY SPORTS COMPLEX
AMES FIELD
MICHIGAN CITY, INDIANA

PROJECT NO. 93052


DATE MAY 31, 1984

drawn by: MFM

checked by: GKJ


A301

ELEVATIONS
FOOTBALL GRANDSTAND

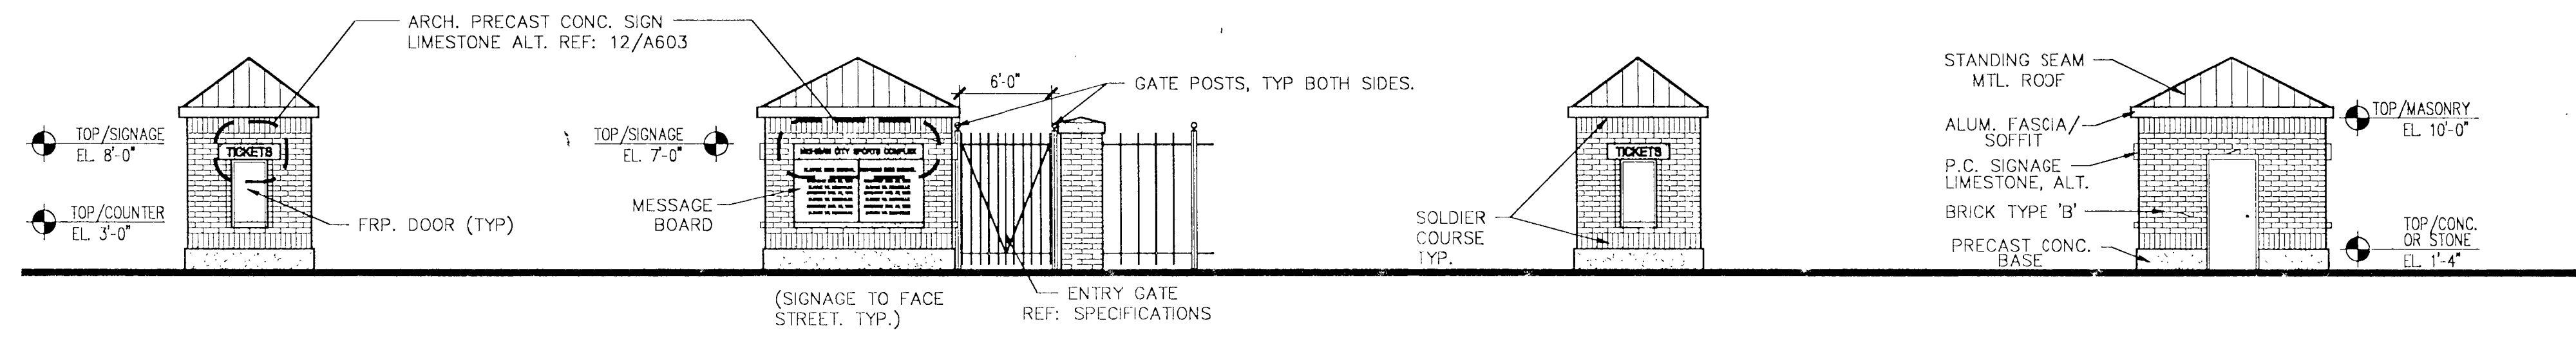


TYPICAL TICKET BOOTH ELEVATIONS

SCALE: 1/8" = 1'-0"

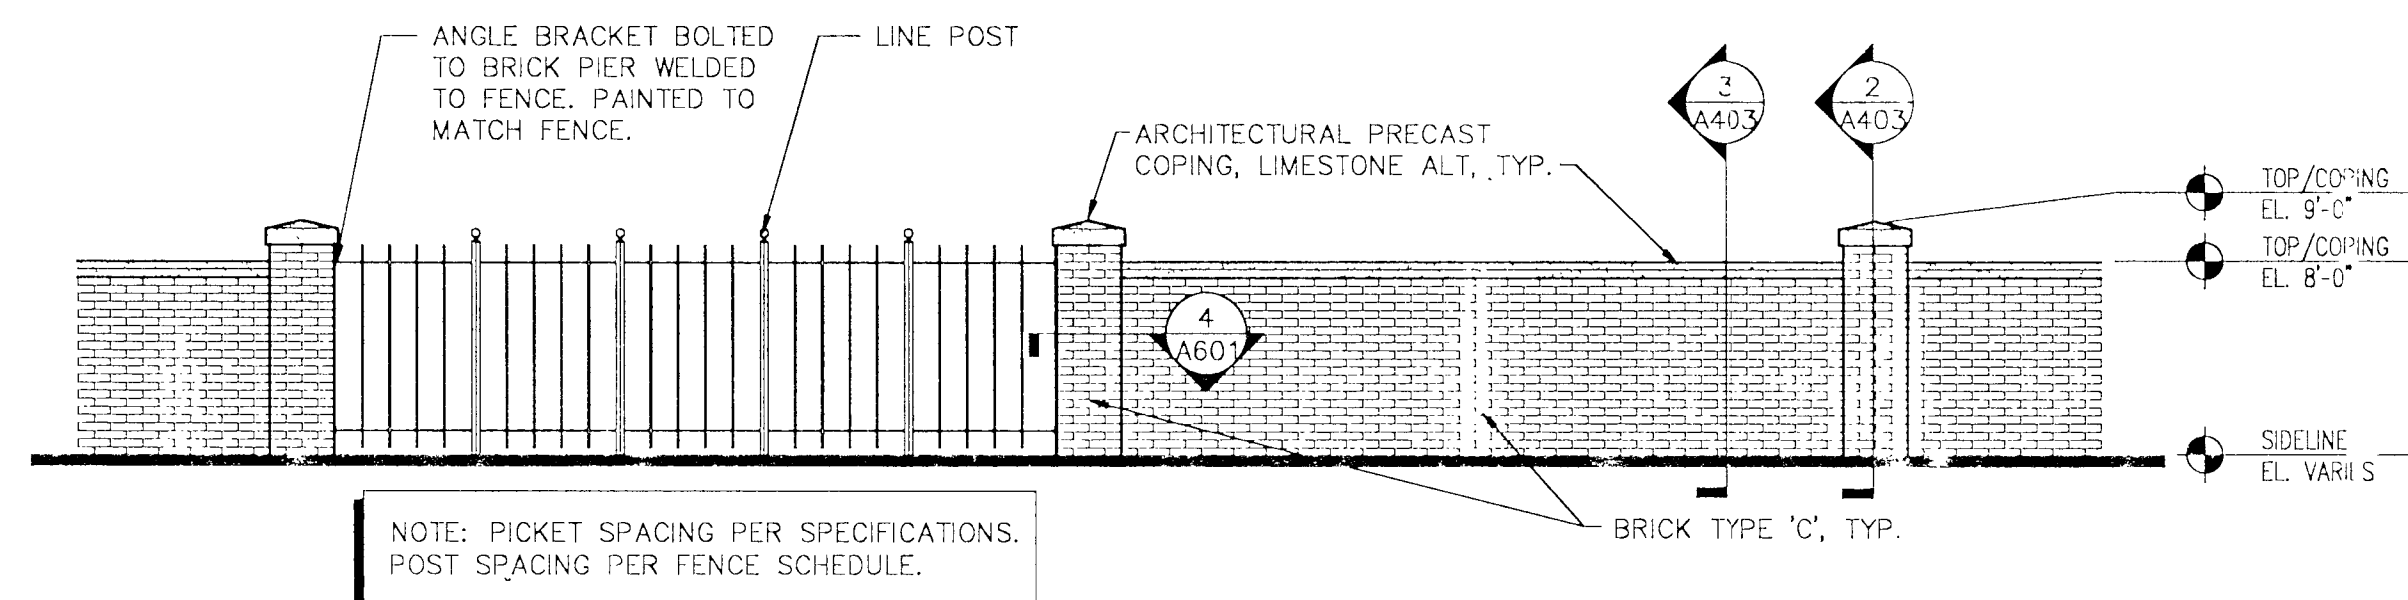

SITE WALL AND FENCE ELEVATION


SCALE: 1/8" = 1'-0"

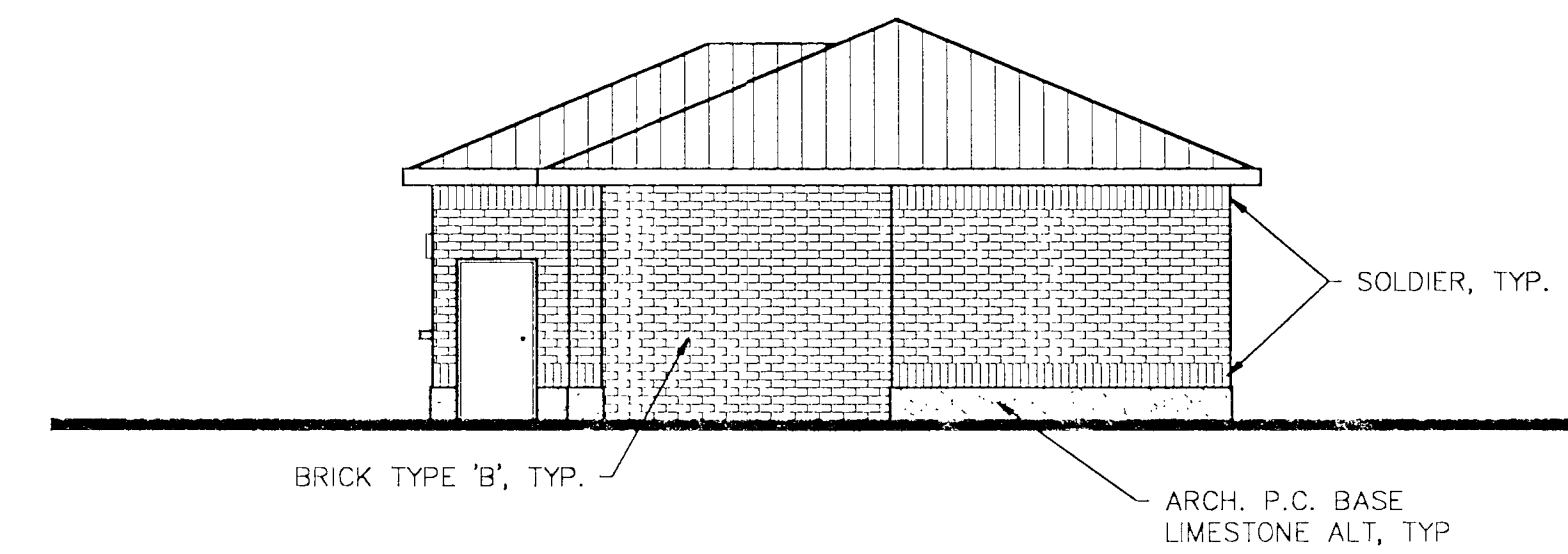

VISITOR TOILET AND CONCESSION WEST ELEVATION


SCALE: 1/8" = 1'-0"

(NOTE: EAST ELEVATION OPPOSITE HAND)

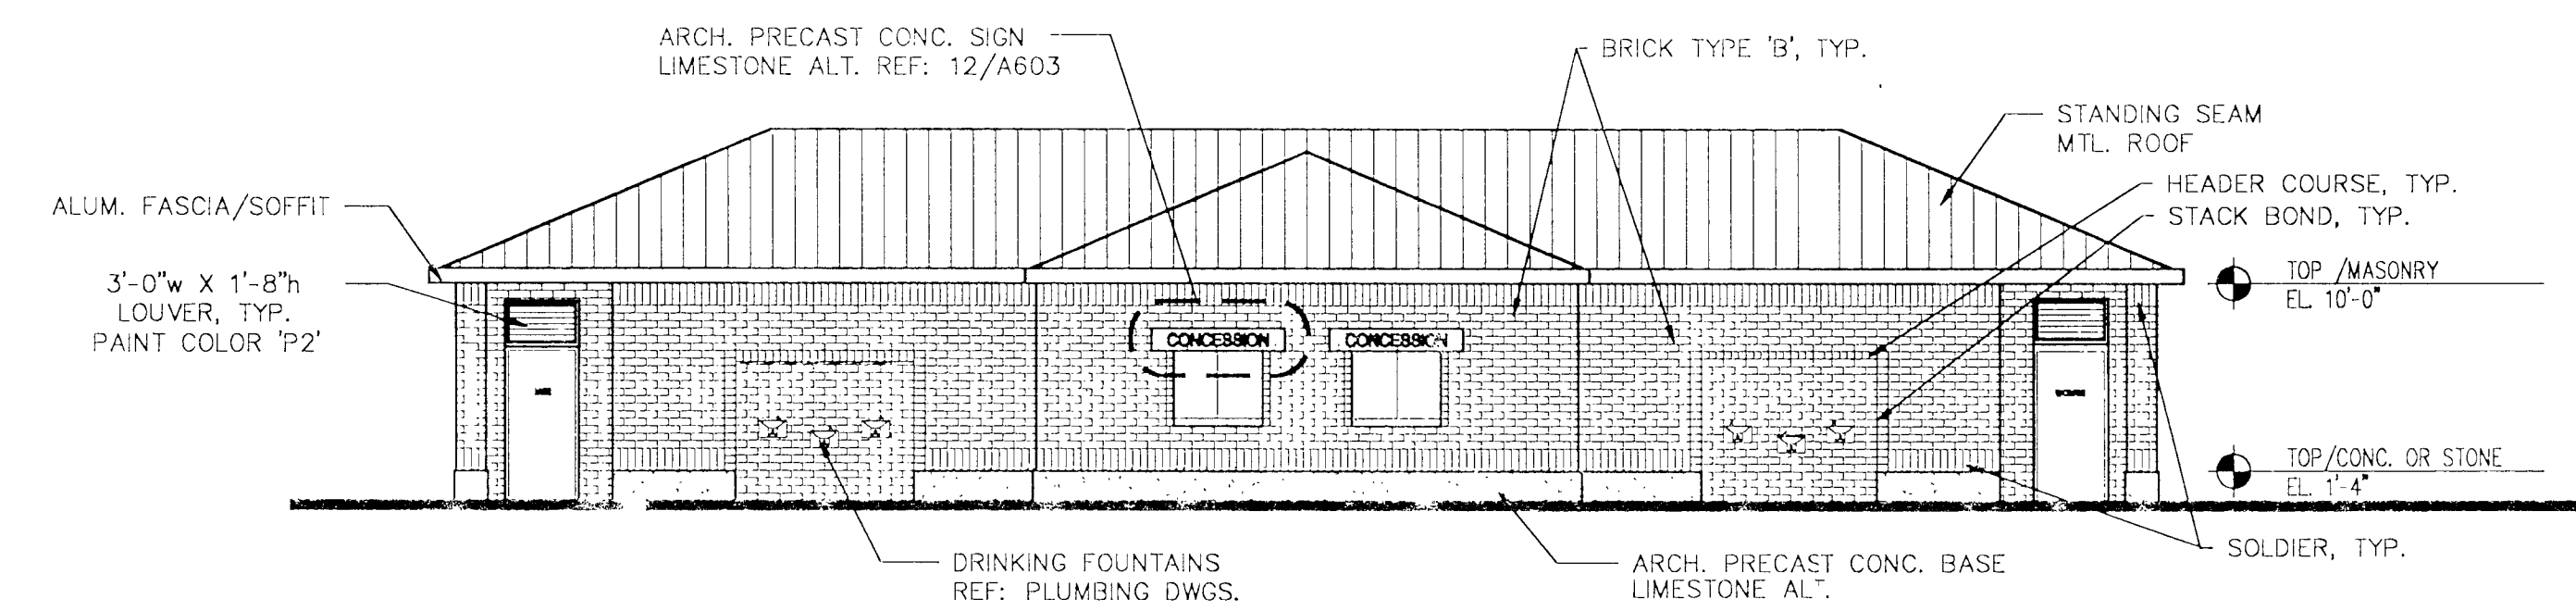

VISITOR TOILET & CONCESSION NORTH ELEVATION


SCALE: 1/8" = 1'-0"

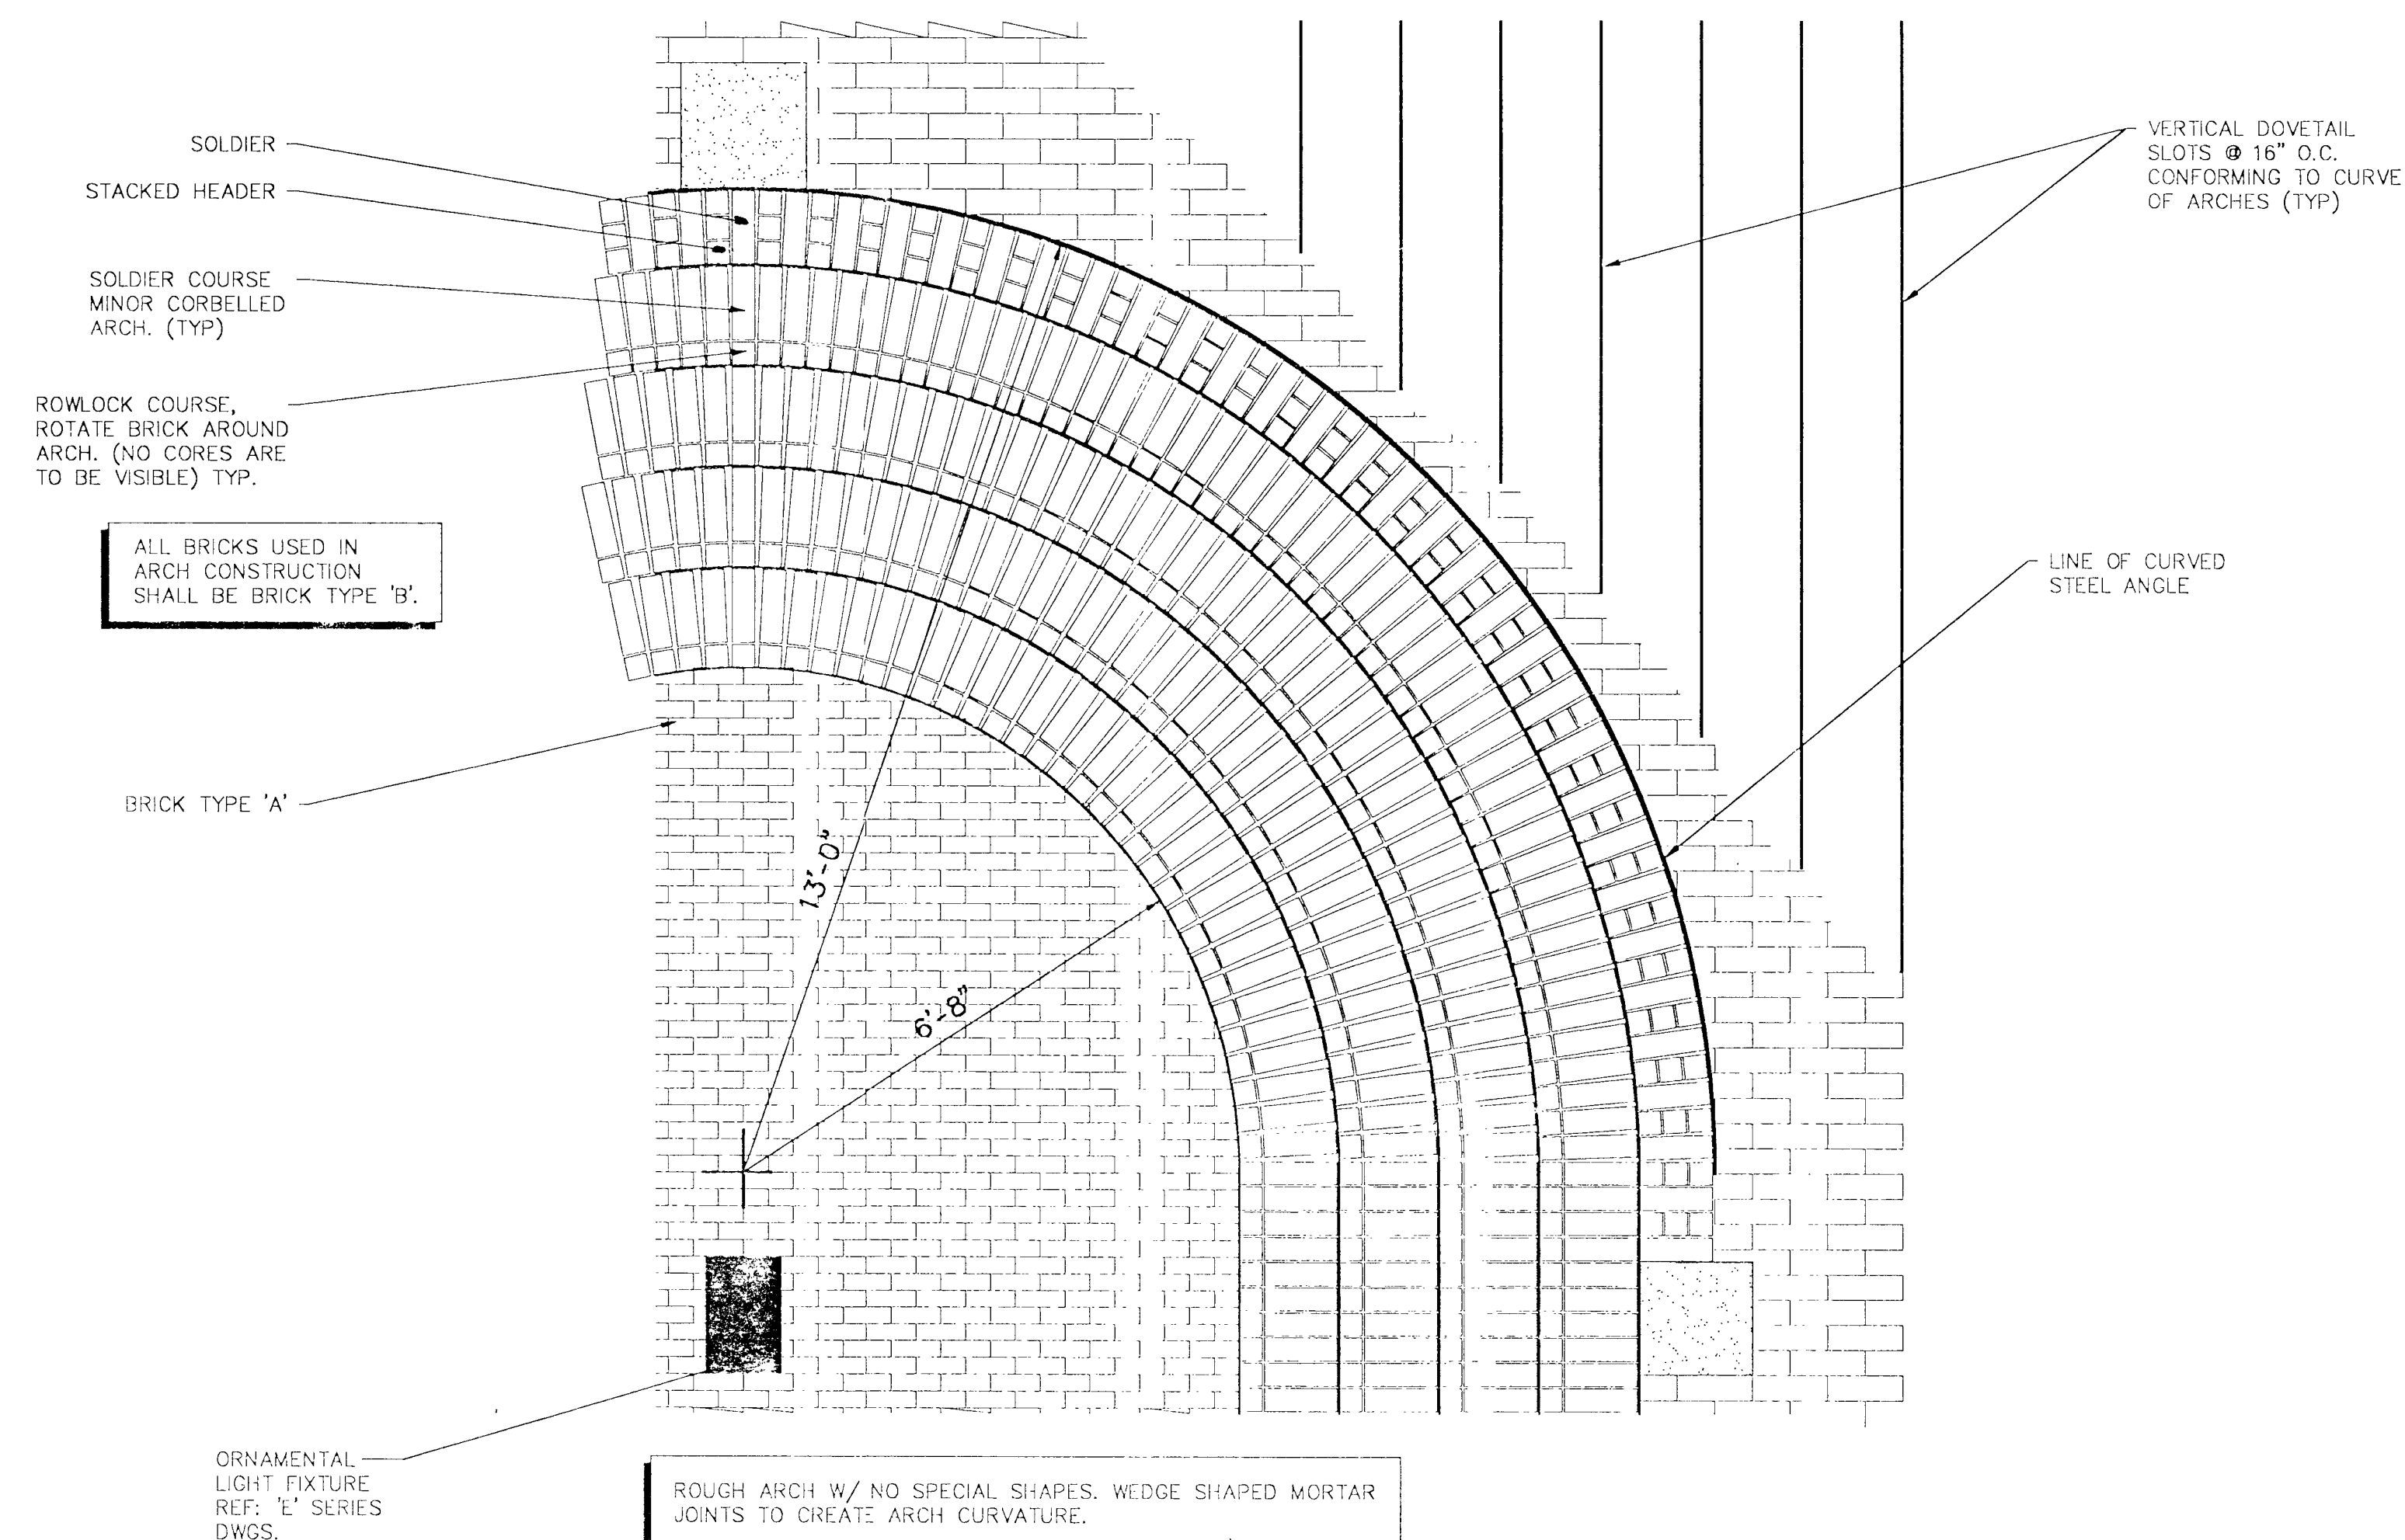

ARCH ENLARGEMENT DETAIL

SCALE: 1/2" = 1'-0"

1 A302

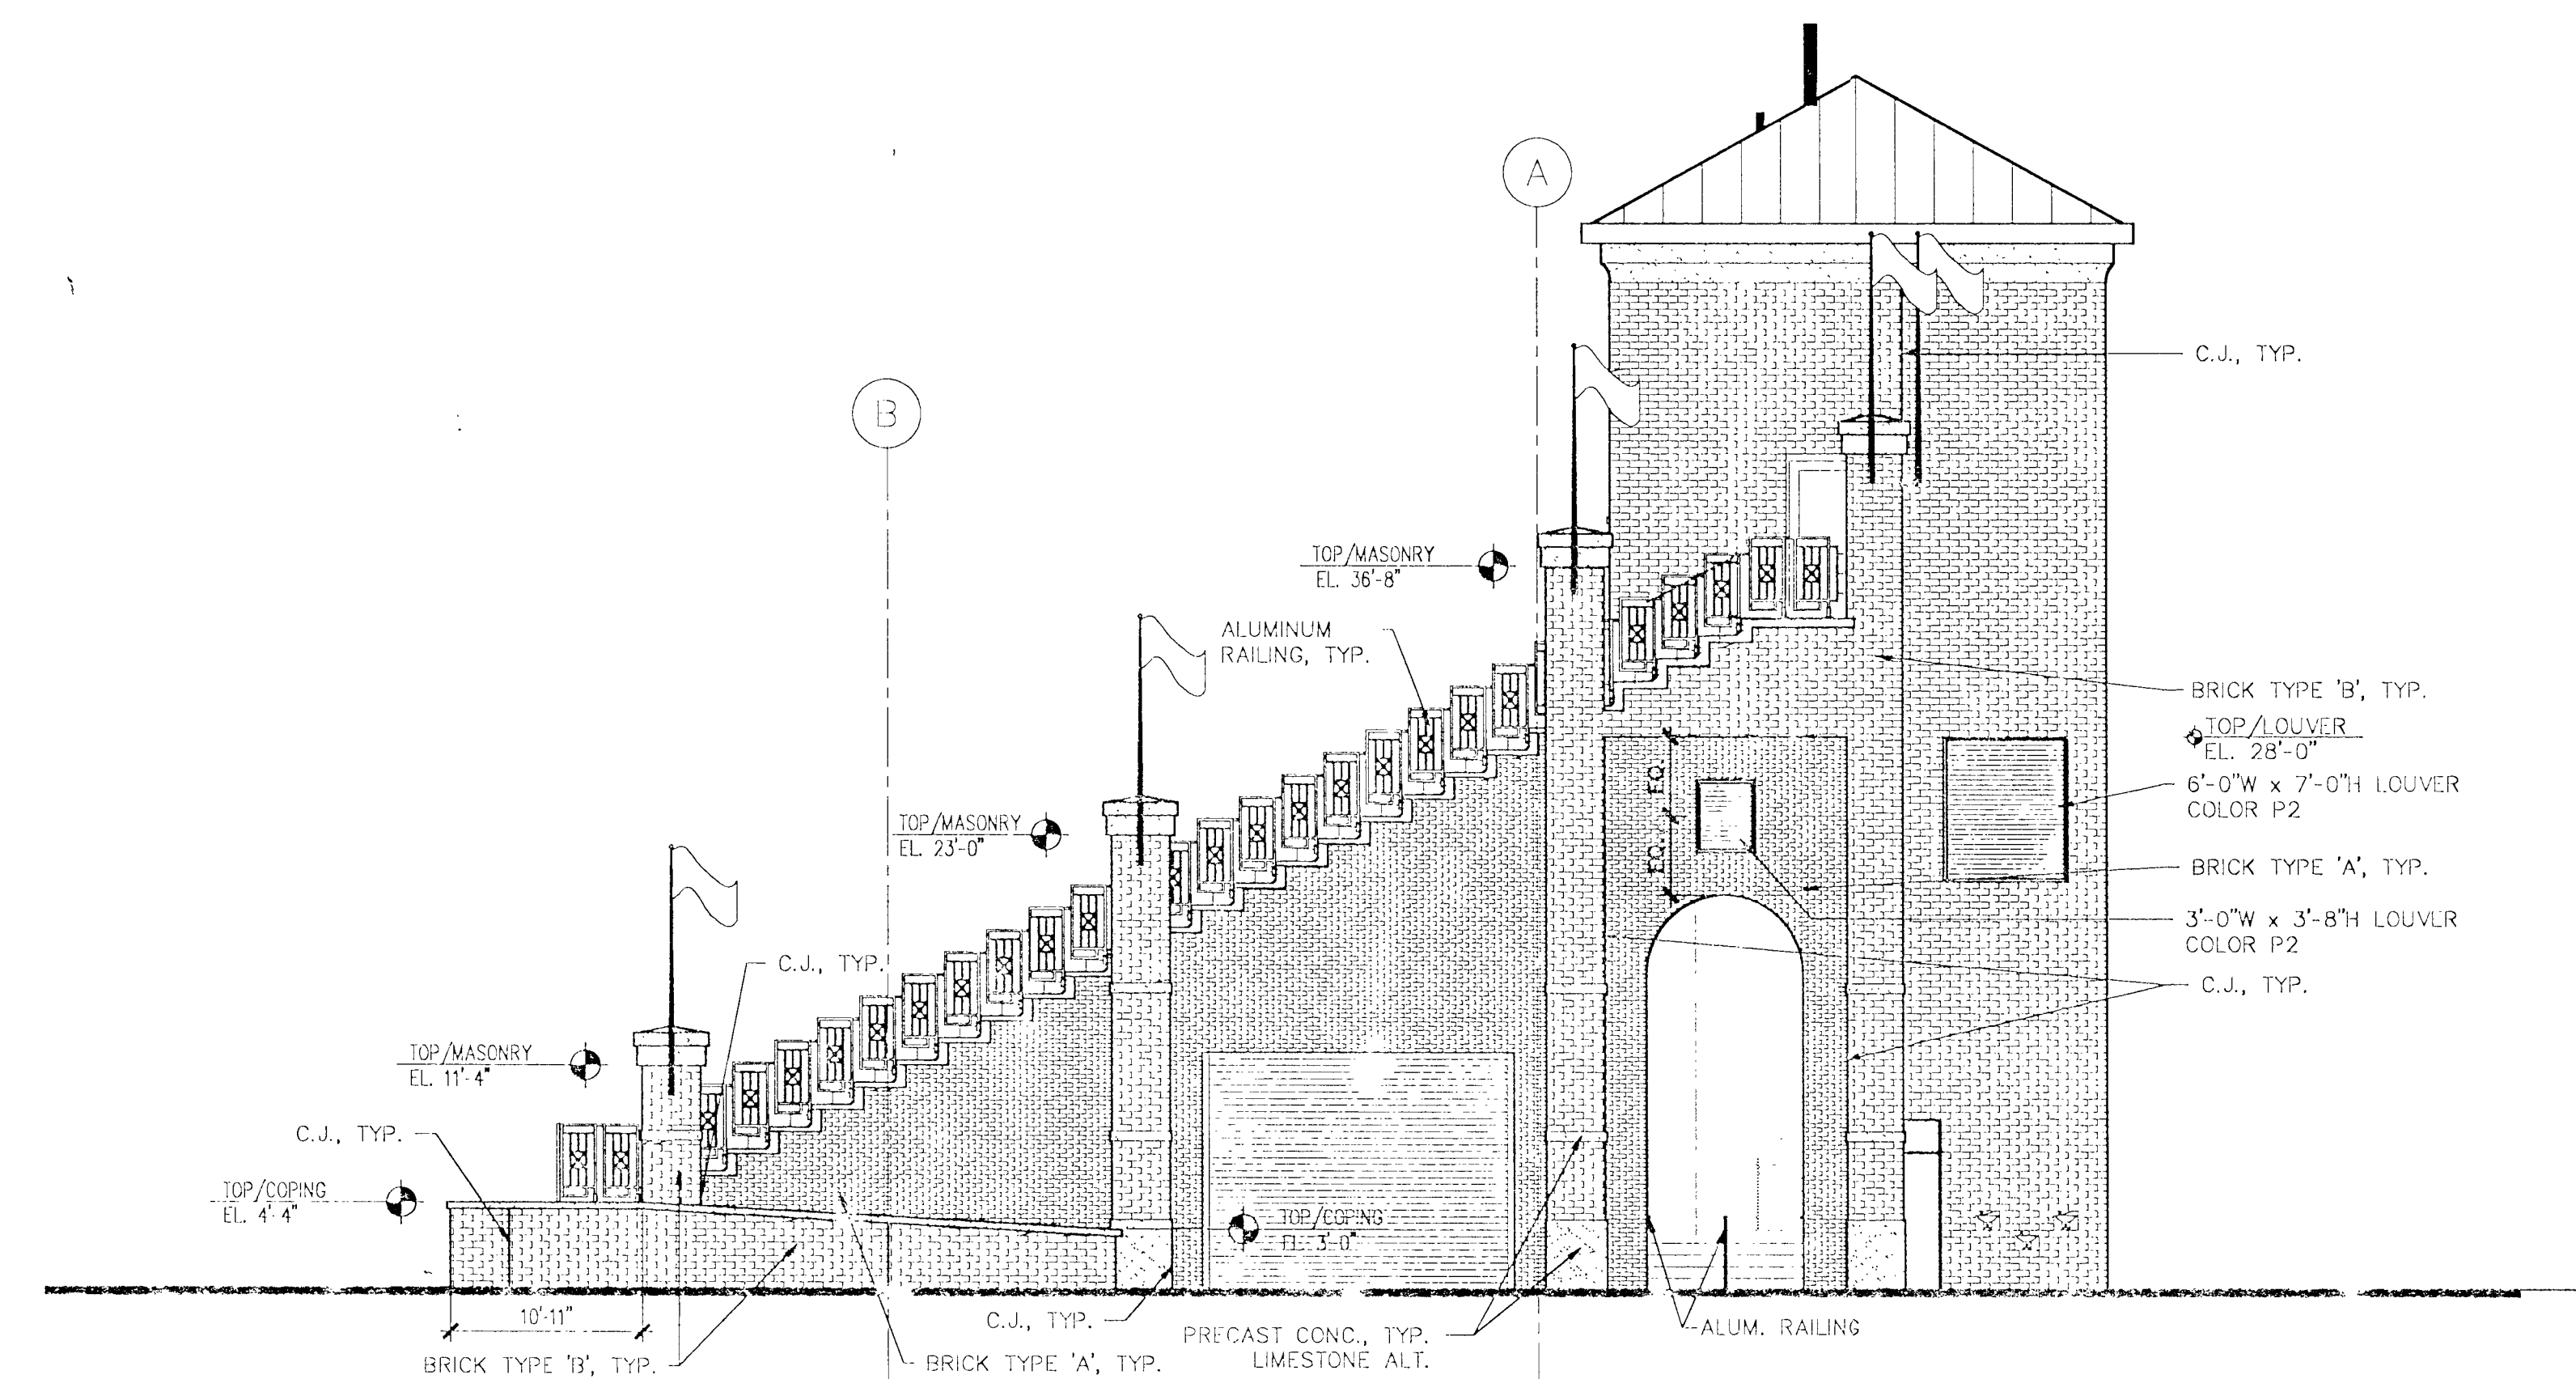


FOOTBALL GRANDSTAND WEST ELEVATION

SCALE: 1/8" = 1'-0"

(NOTE: EAST ELEVATION OPPOSITE HAND)

NOTE: BRICK IS SHOWN AS GRAPHIC INDICATION
ONLY. REF. SECTION 0400 IN PROJECT MANUAL
NOTES, WALL SECTIONS AND REFERENCED DETAILS
FOR BRICK SIZES AND BOND PATTERN.

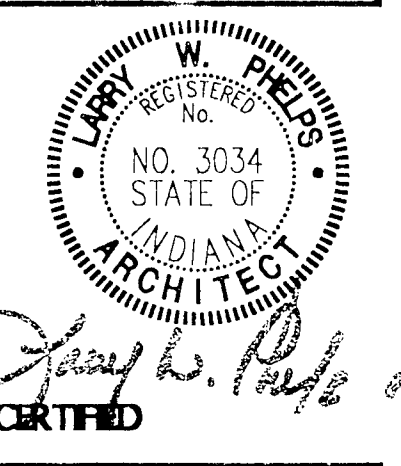

THE ODLE MCCUIRE & SHOOK CORPORATION
ARCHITECTURE • ENGINEERING • LANDSCAPE ARCHITECTURE • INTERIOR DESIGN
6765 NORTH STATE ROAD 37, POST OFFICE BOX 2149, BLOOMINGTON, INDIANA 47402, 812/876-2020
8275 ALISON PONTE TRAIL, POST OFFICE BOX 50428, INDIANAPOLIS, INDIANA 46250, 317/842-0000


REVISIONS

© Copyright 1994 by THE ODLE MCCUIRE & SHOOK CORPORATION. Copyright includes architectural work, building design, plans or drawings, and specifications. Architectural work in the world form as well as the arrangement and composition of spaces and elements in the design. Reproduction without written permission is prohibited.

MICHIGAN CITY SPORTS COMPLEX
AMES FIELD
MICHIGAN CITY, INDIANA

PROJECT NO. 93052
DATE MAY 31, 1994
drawn by: MEMCOWPAM
checked by: GKJ


A302
ELEVATIONS
FOOTBALL GRANDSTAND
VISITOR TOILET/CONCESSION
SITE WALL / FENCE

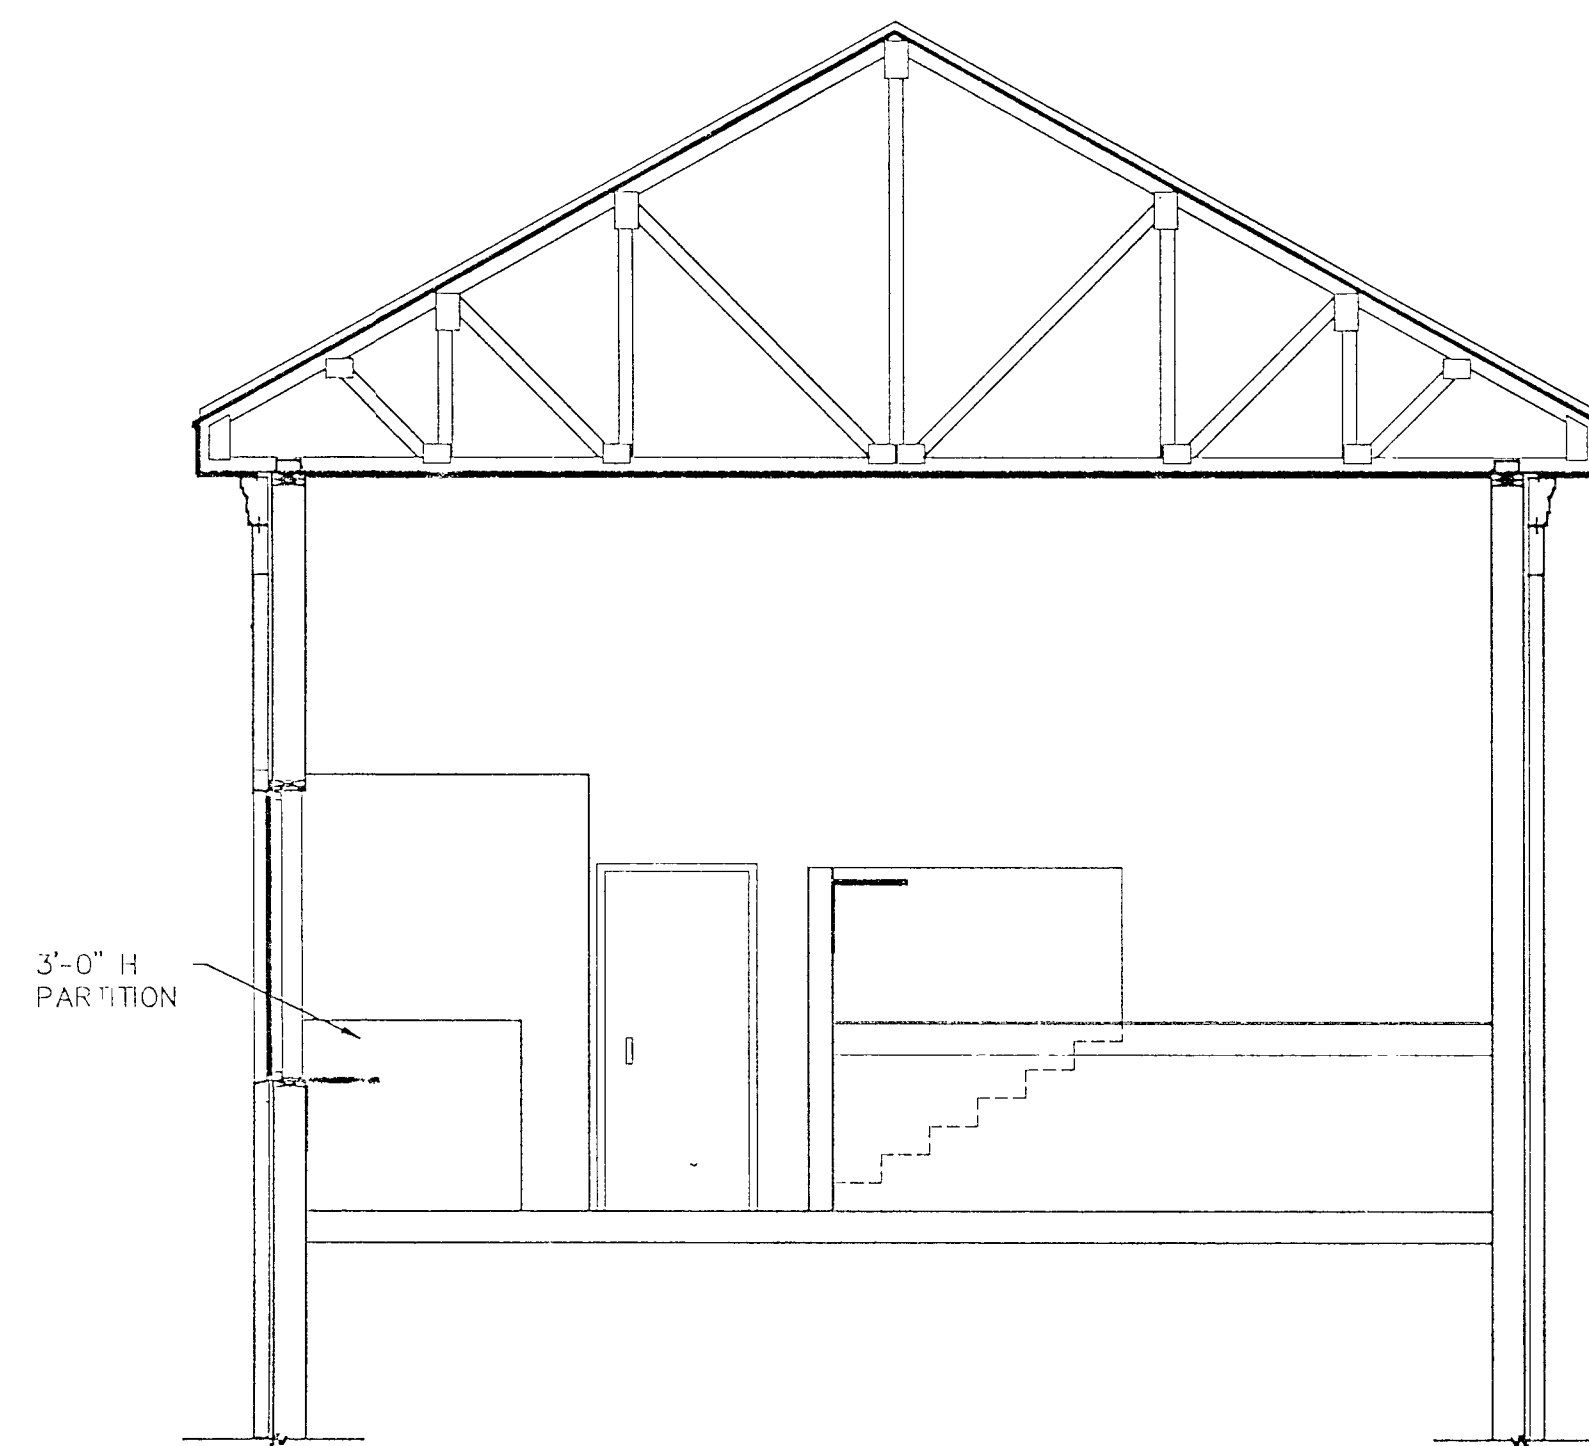

SECTION THROUGH FOOTBALL PRESSBOX

SCALE: 1/4"=1'-0"


6
A303

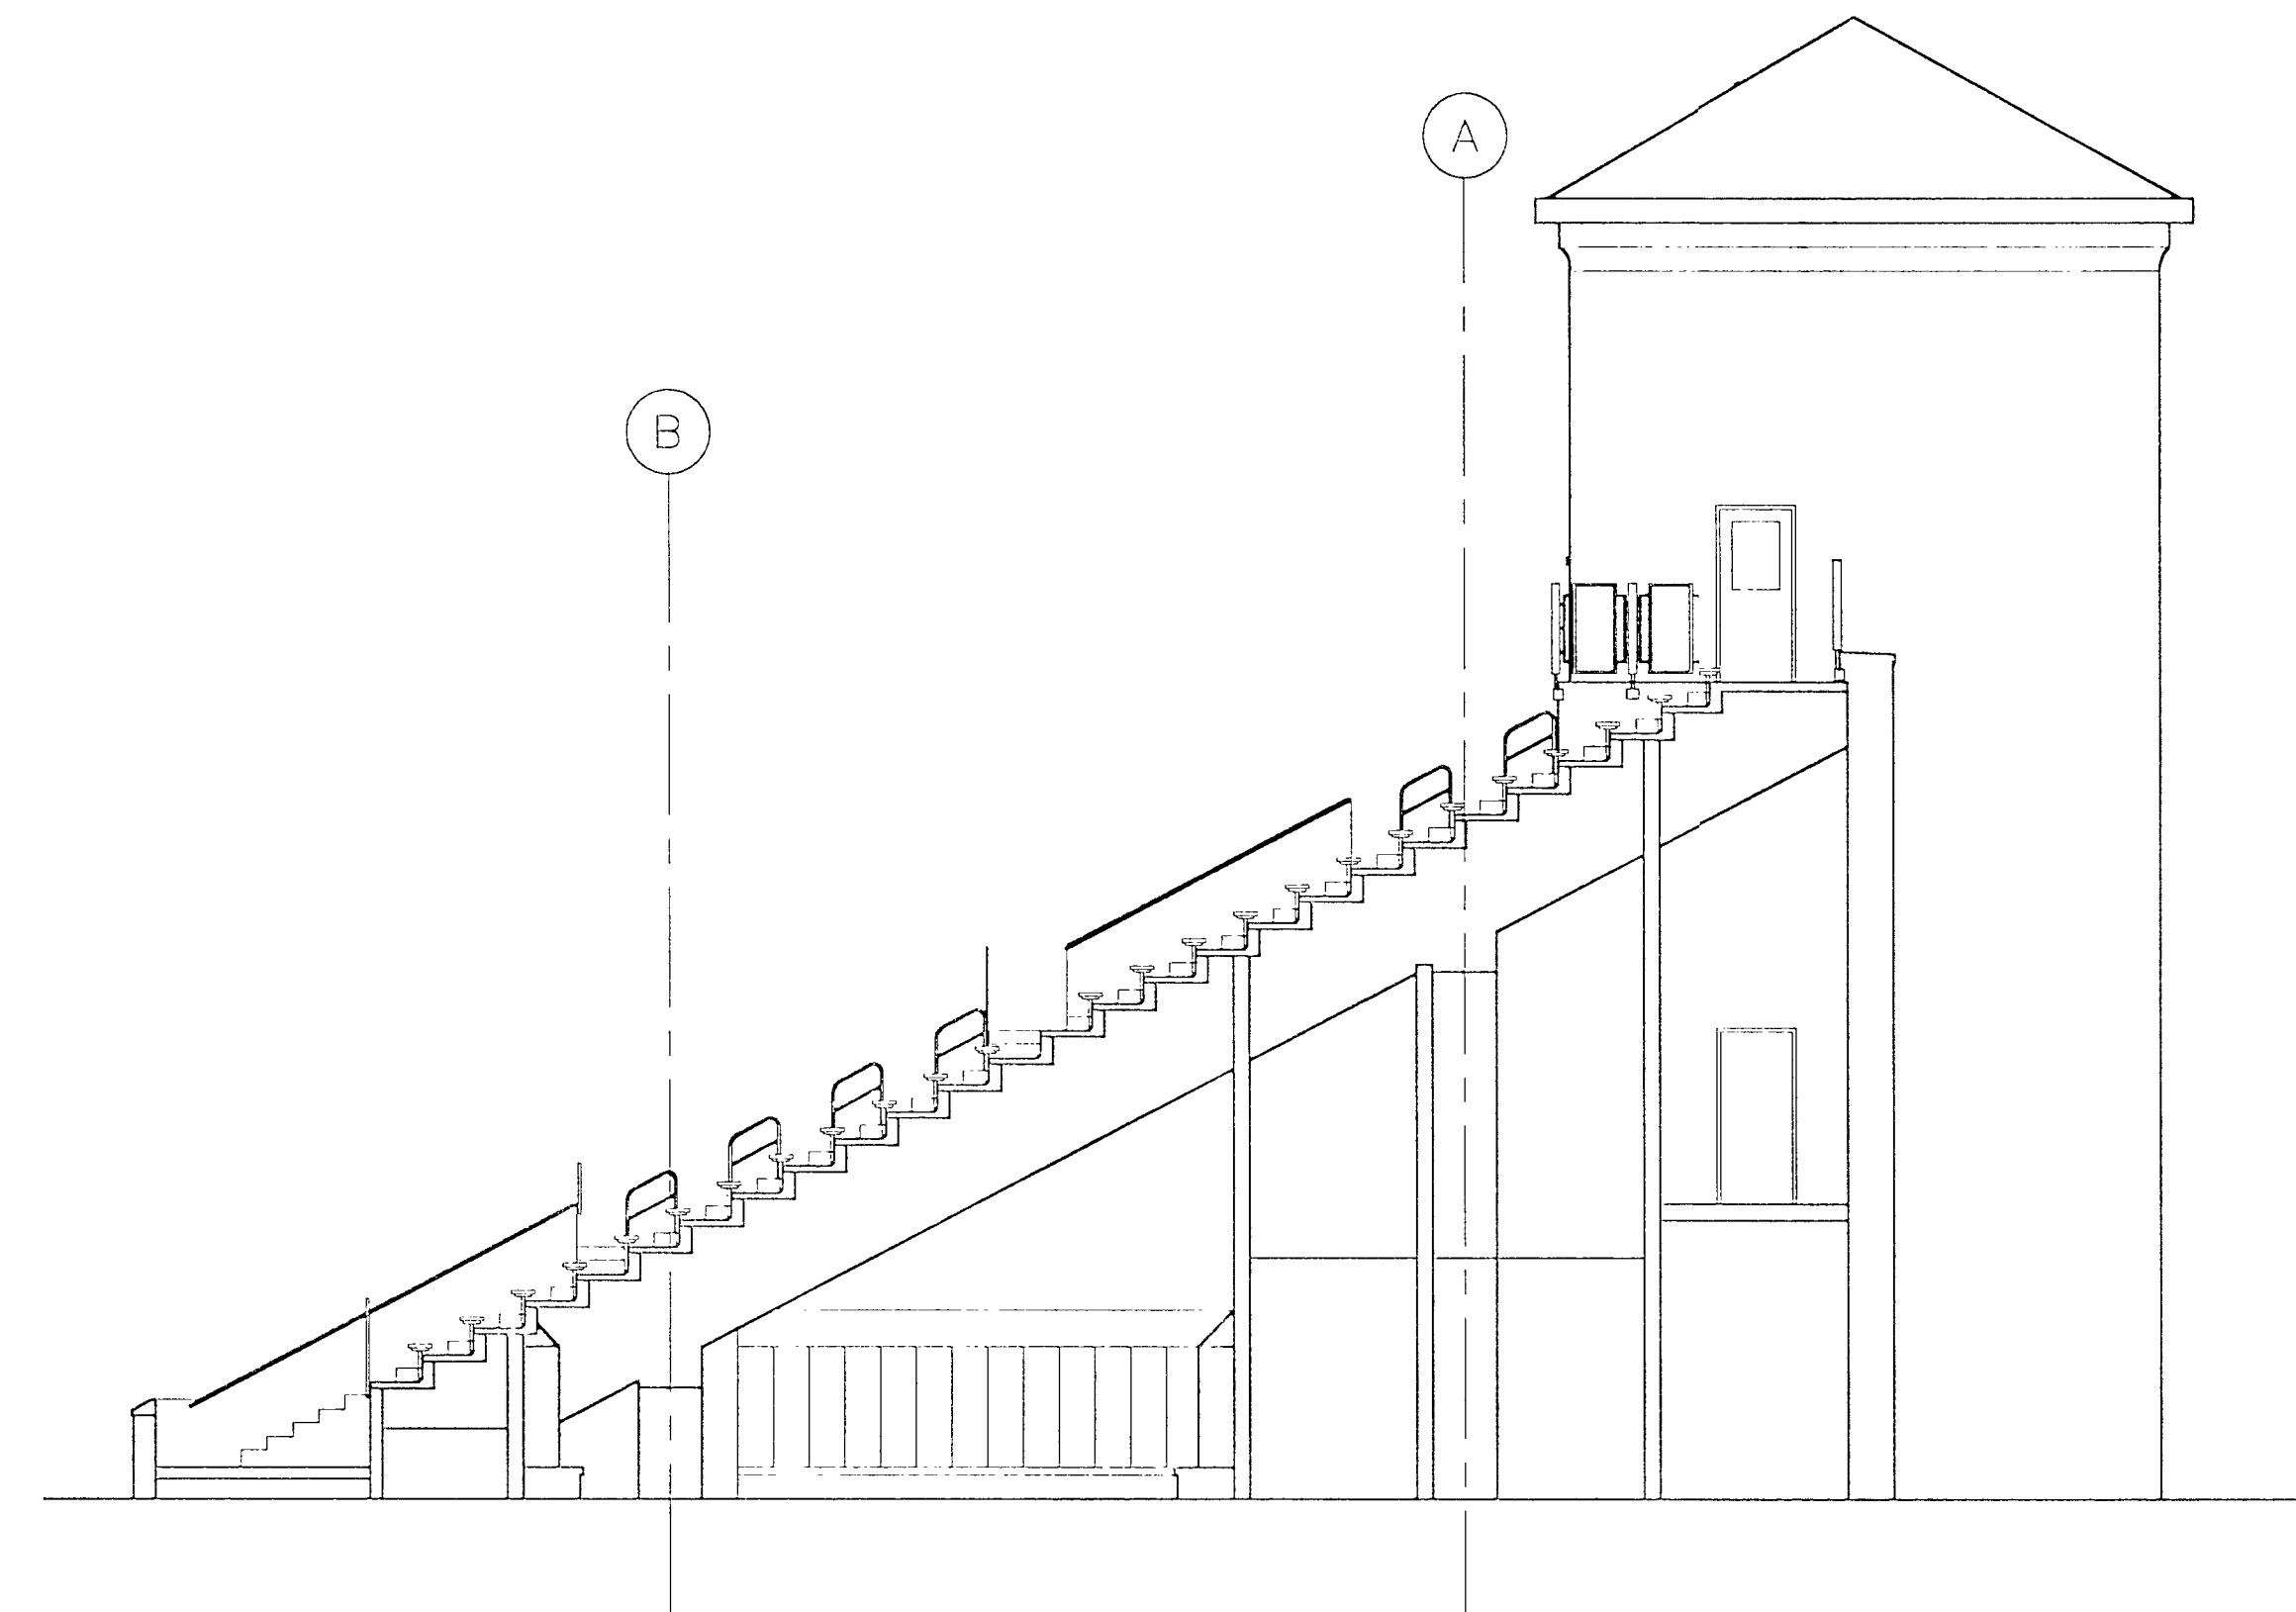

FOOTBALL GRANDSTAND SECTION

SCALE: 1/8"=1'-0"


5
A303

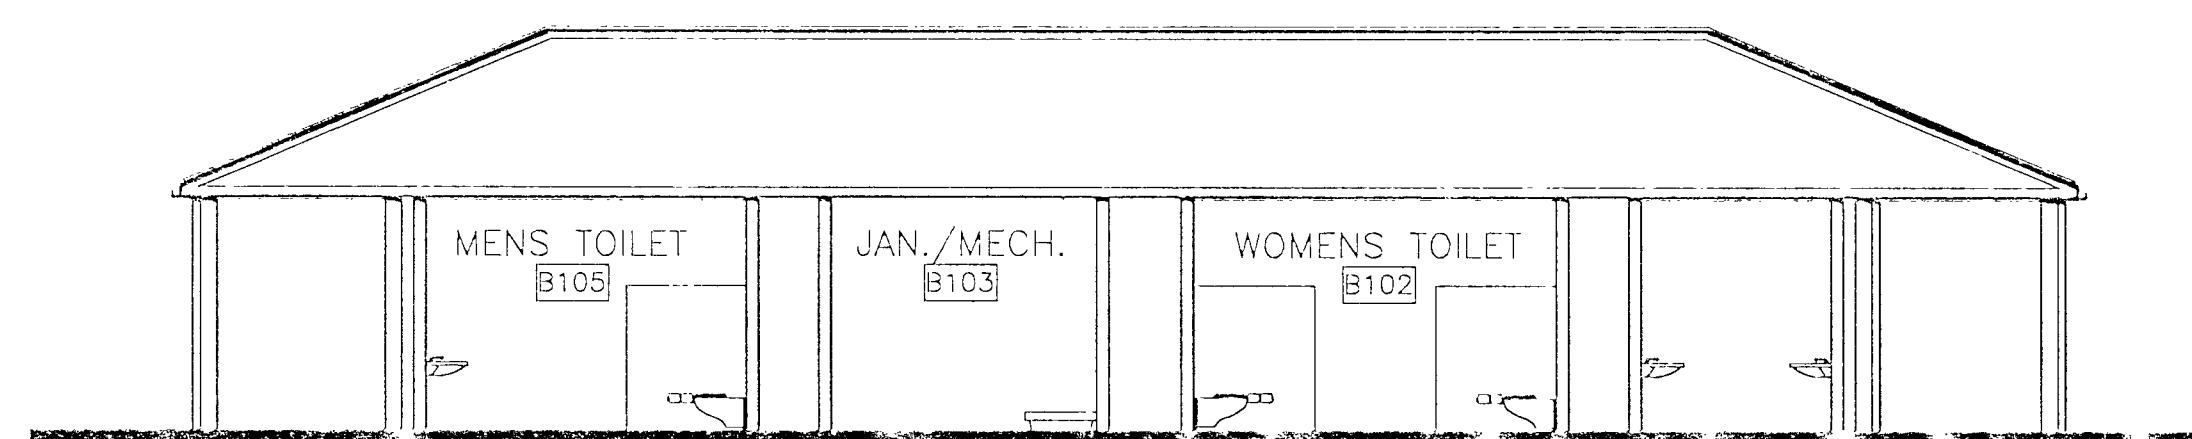

SECTION THROUGH VISITOR
TOILET/CONCESSION

SCALE: 1/8"=1'-0"


4
A303

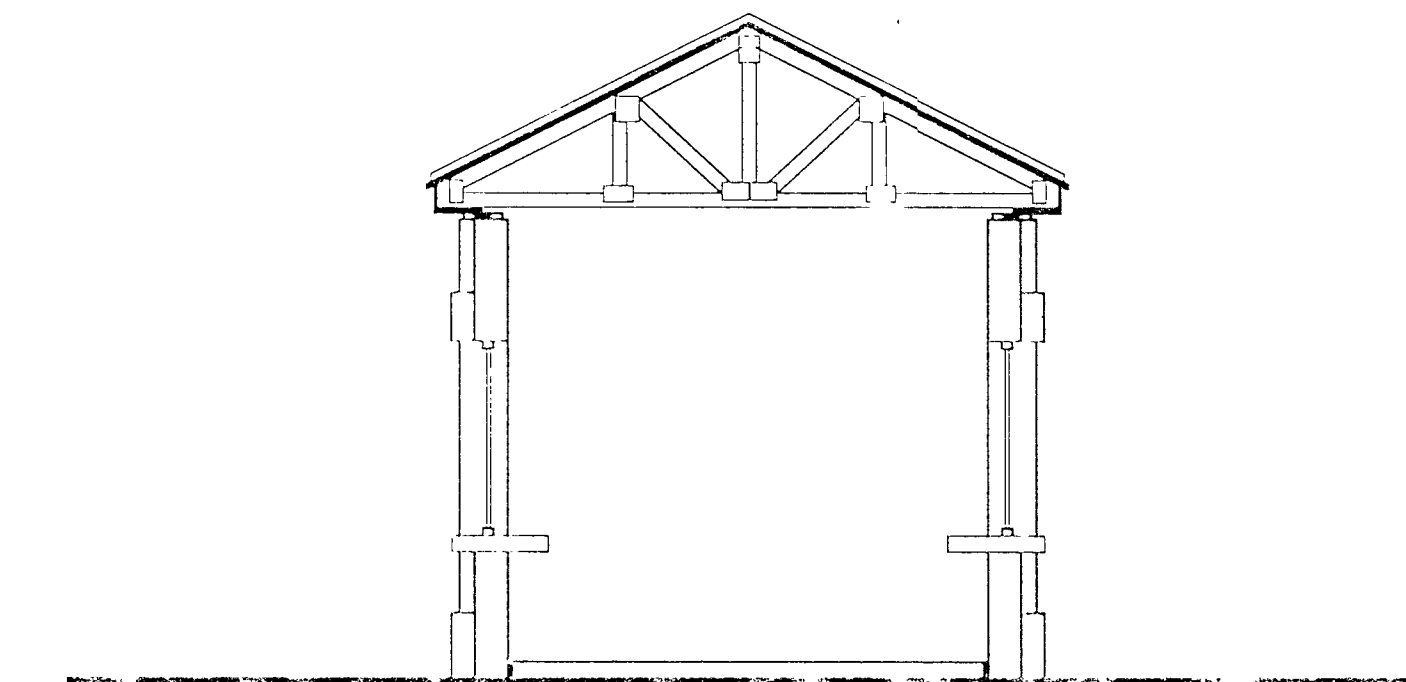

TYP. SECTION THROUGH
TICKET BOOTH

SCALE: 1/4"=1'-0"


3
A303

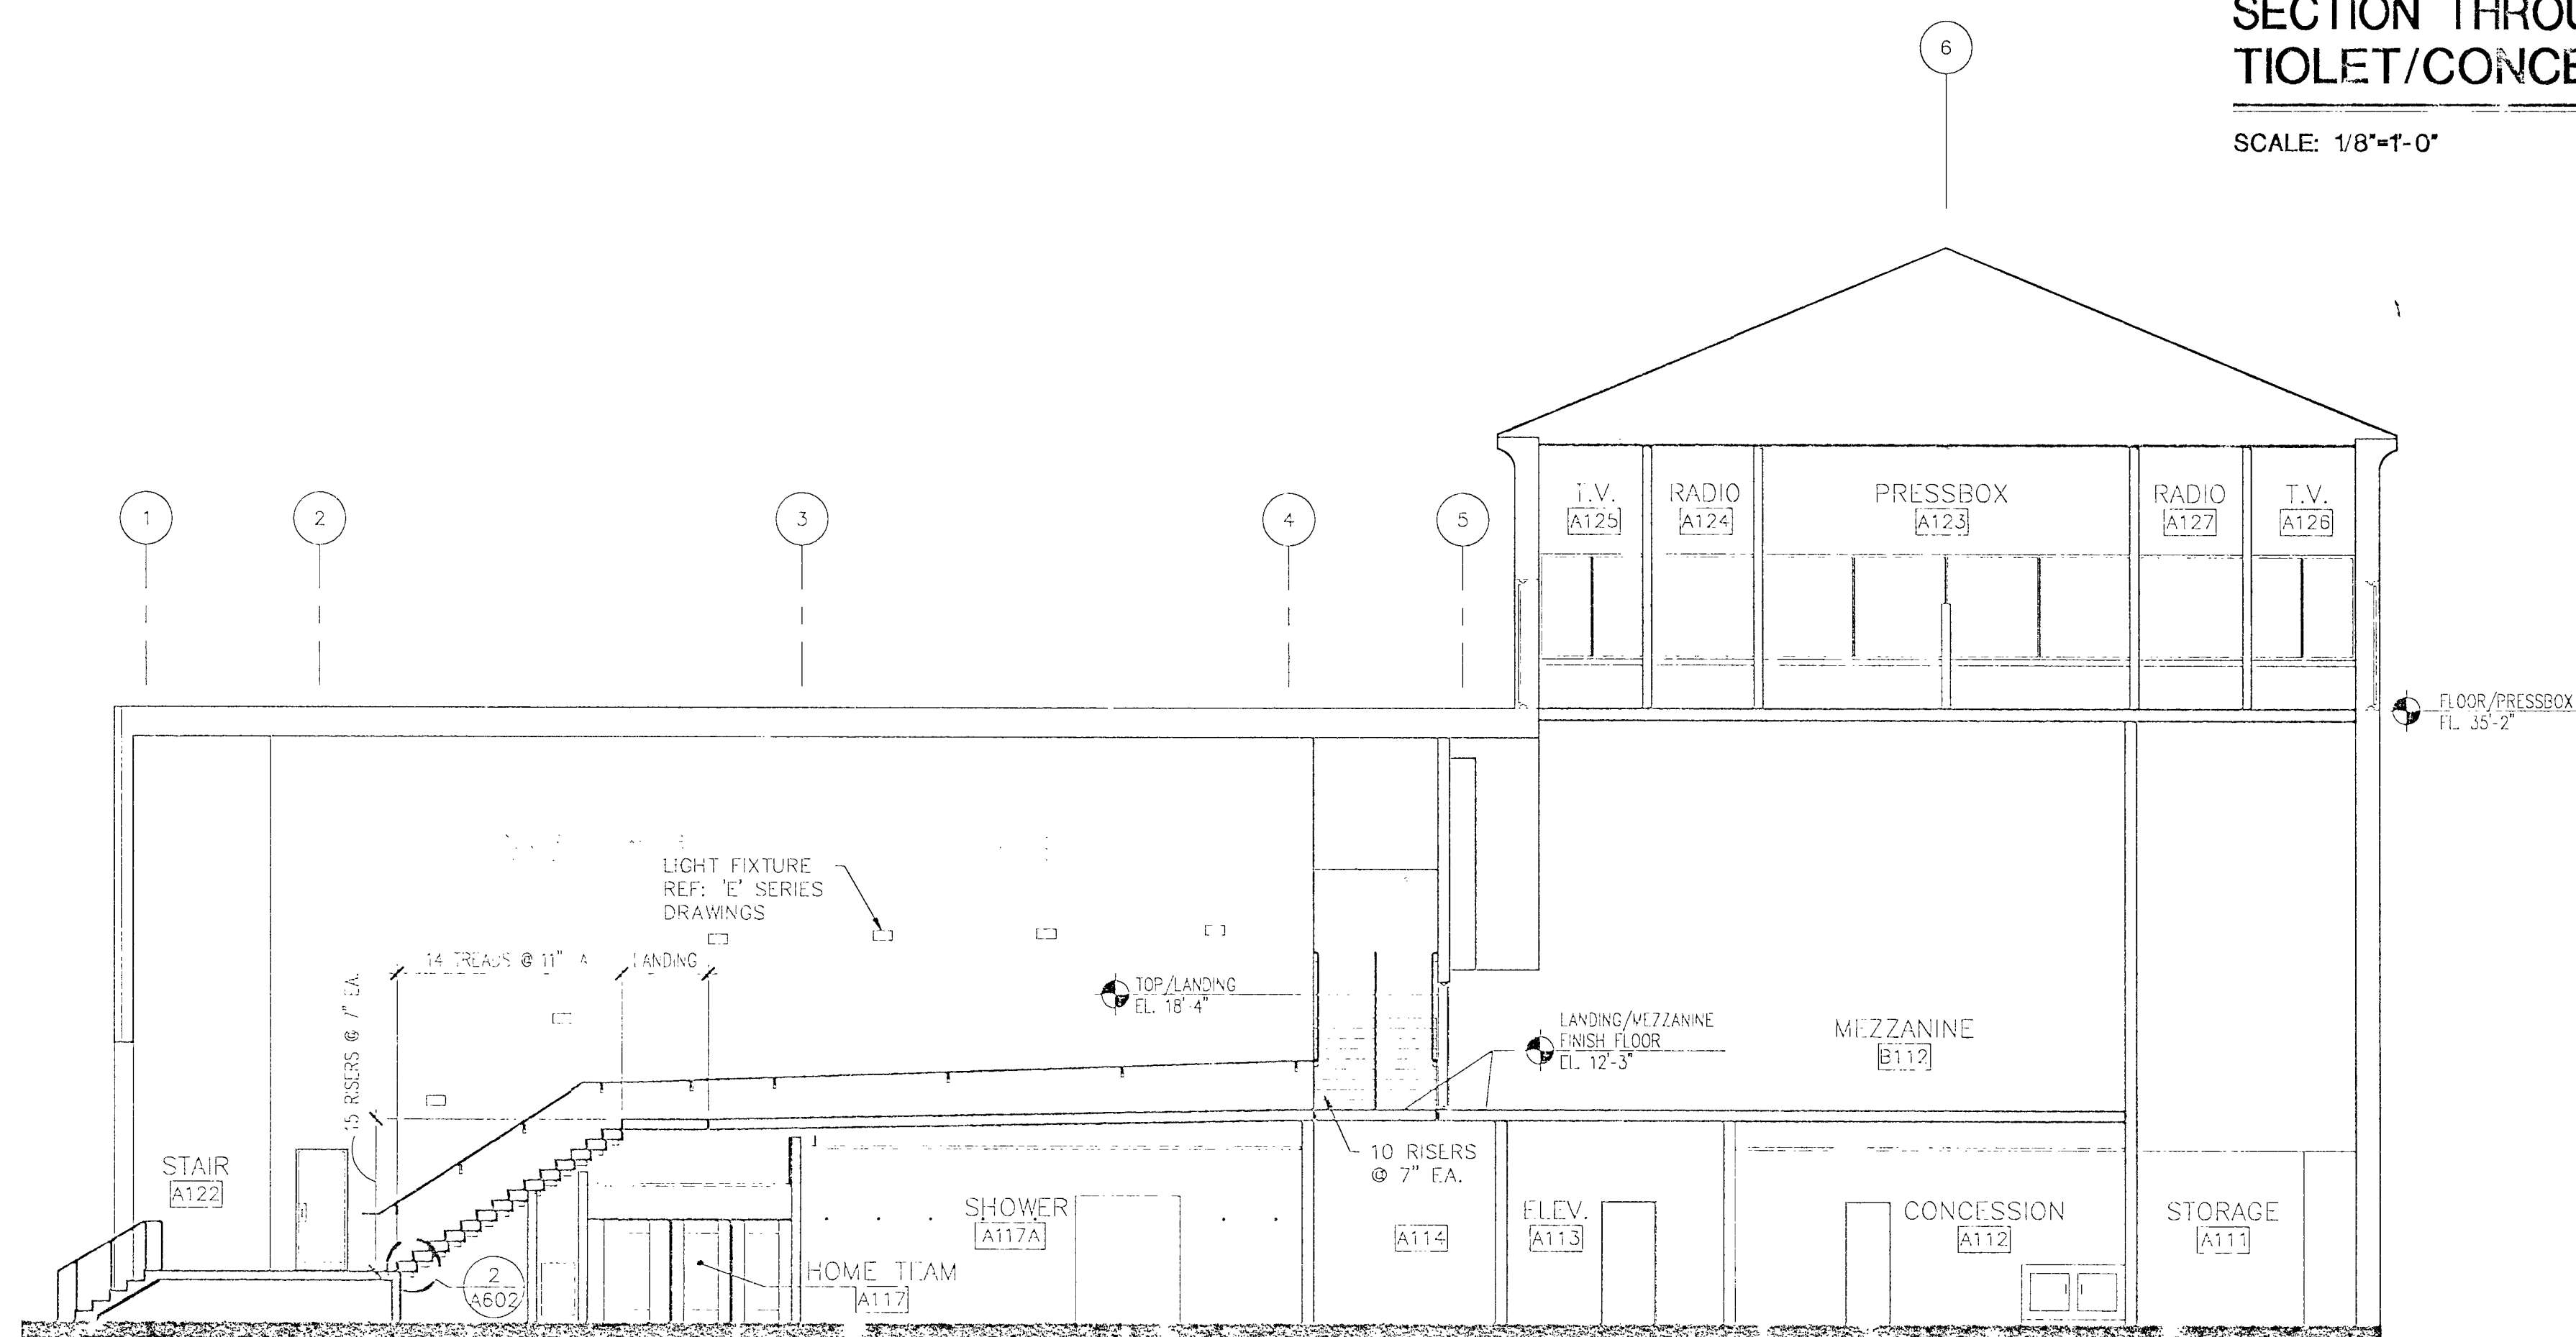

LONGITUDINAL SECTION THROUGH FOOTBALL GRANDSTAND

SCALE: 1/8"=1'-0"


2
A303

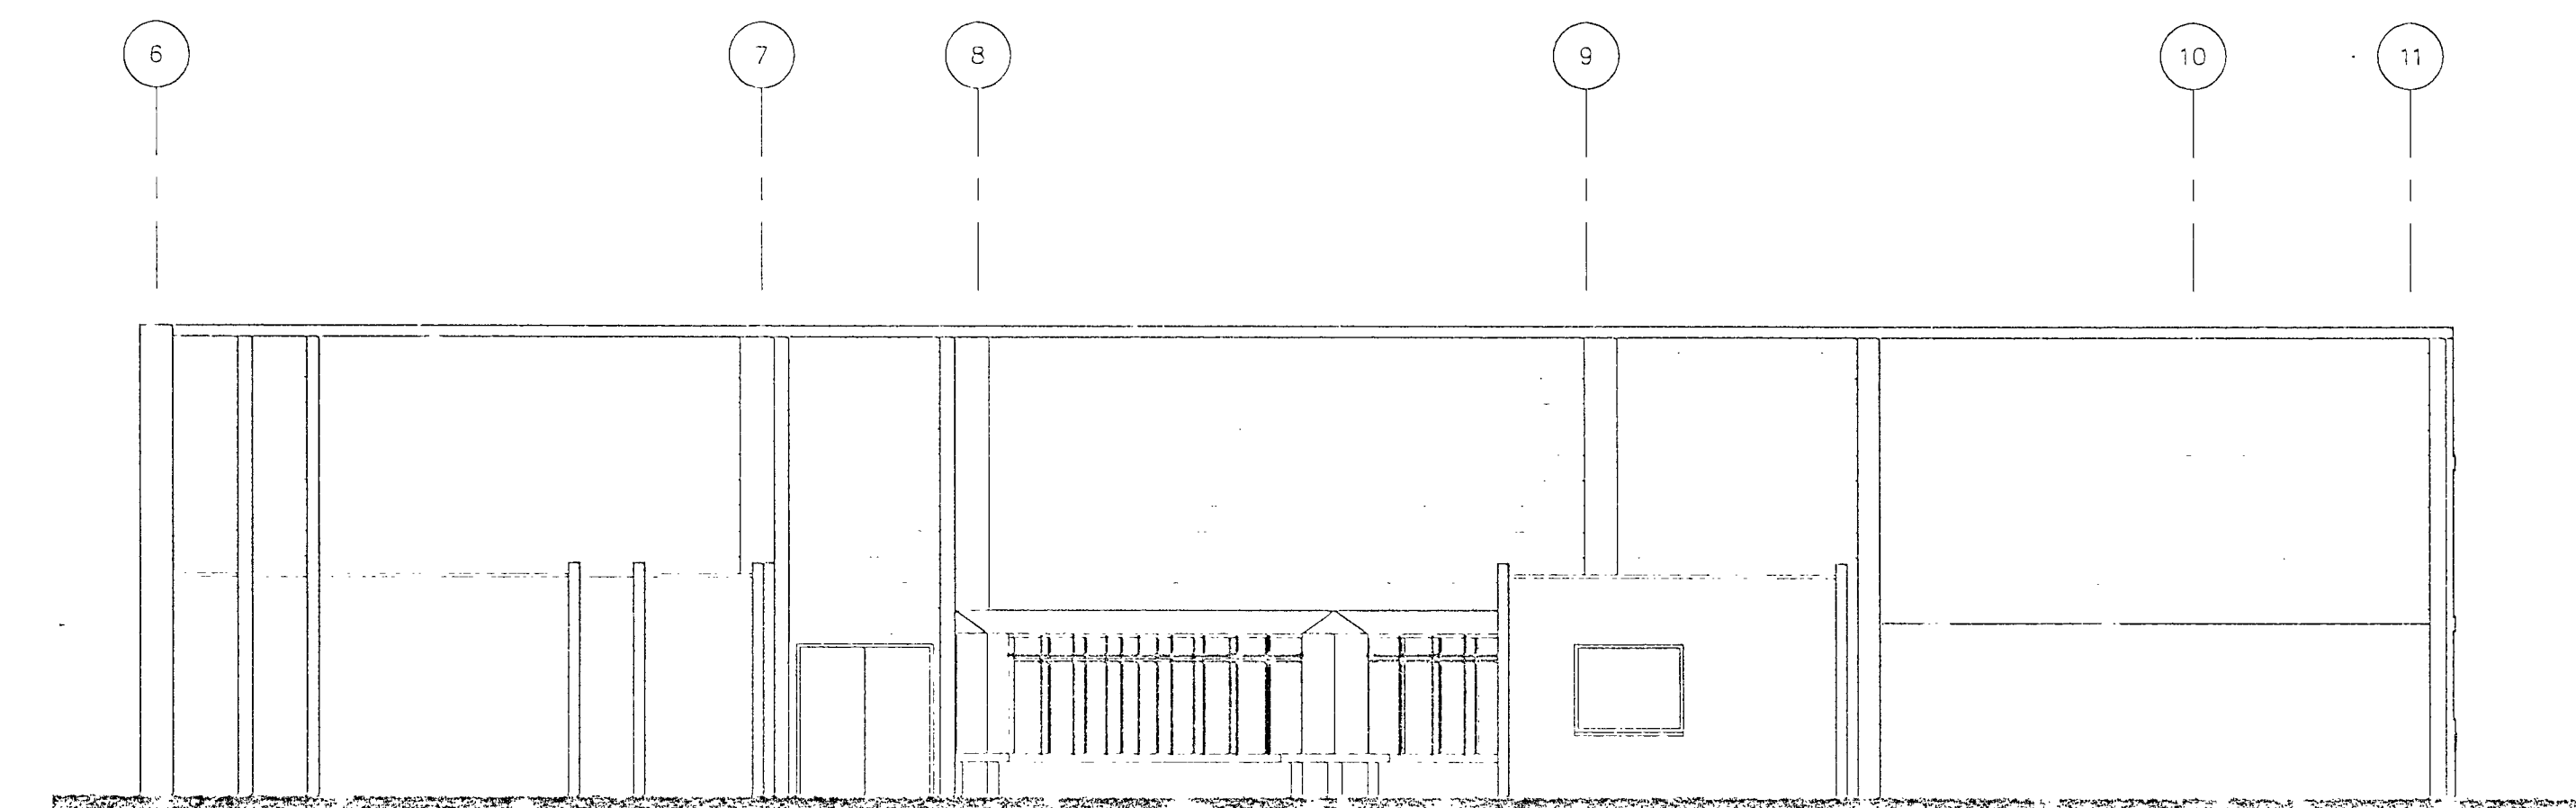

LONGITUDINAL SECTION THROUGH FOOTBALL GRANDSTAND

SCALE: 1/8"=1'-0"

1
A303

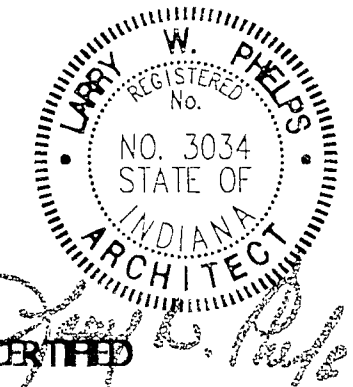

THE ODLÉ MCGUIRE & SHOOK CORPORATION
ARCHITECTURE • ENGINEERING • LANDSCAPE ARCHITECTURE • INTERIOR DESIGN
6765 NORTH STATE ROAD 37, POST OFFICE BOX 2149, BLOOMINGTON, INDIANA 47402, 812/876-2020
8275 ALLISON FORTÉ TRAIL, POST OFFICE BOX 50428, INDIANAPOLIS, INDIANA 46250, 317/542-0000

REVISIONS

© Copyright 1984 by THE ODLÉ MCGUIRE & SHOOK CORPORATION. Copyright includes architectural work, building design, plans or drawings, and specifications. Architectural work is the product of the firm and its employees and is the property of the firm. Reproduction without written permission is prohibited.

MICHIGAN CITY SPORTS COMPLEX
AMES FIELD
MICHIGAN CITY, INDIANA

PROJECT NO. 83052
DATE MAY 31, 1984
drawn by: MRM
checked by: GKJ


A303

BUILDING SECTIONS

1. *Journal of the American Medical Association*, 1997; 277: 1033-1036.



WALL SECTION @ FOOTBALL GRANDSTAND

SCALE: 1/2"=1'-0"

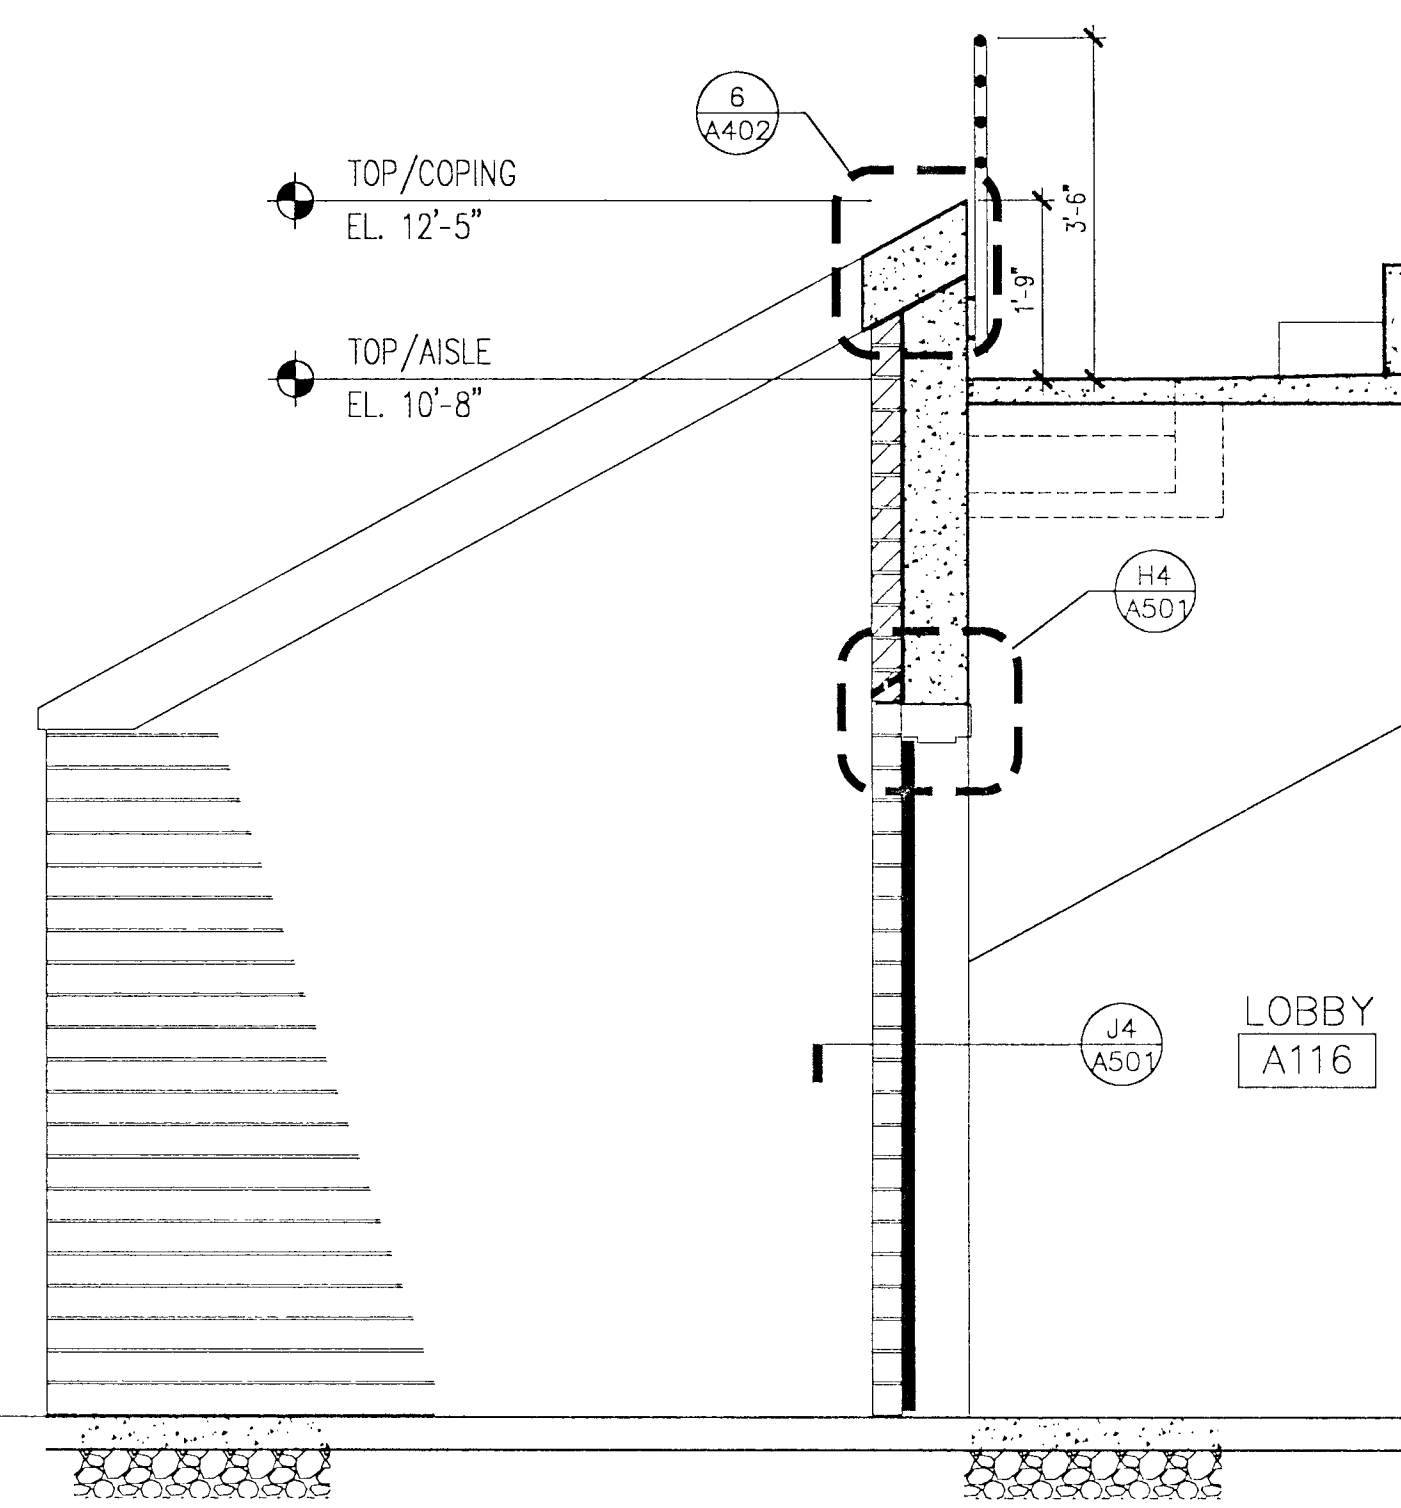

COPING DETAIL

SCALE: 1 1/2" = 1'-0"

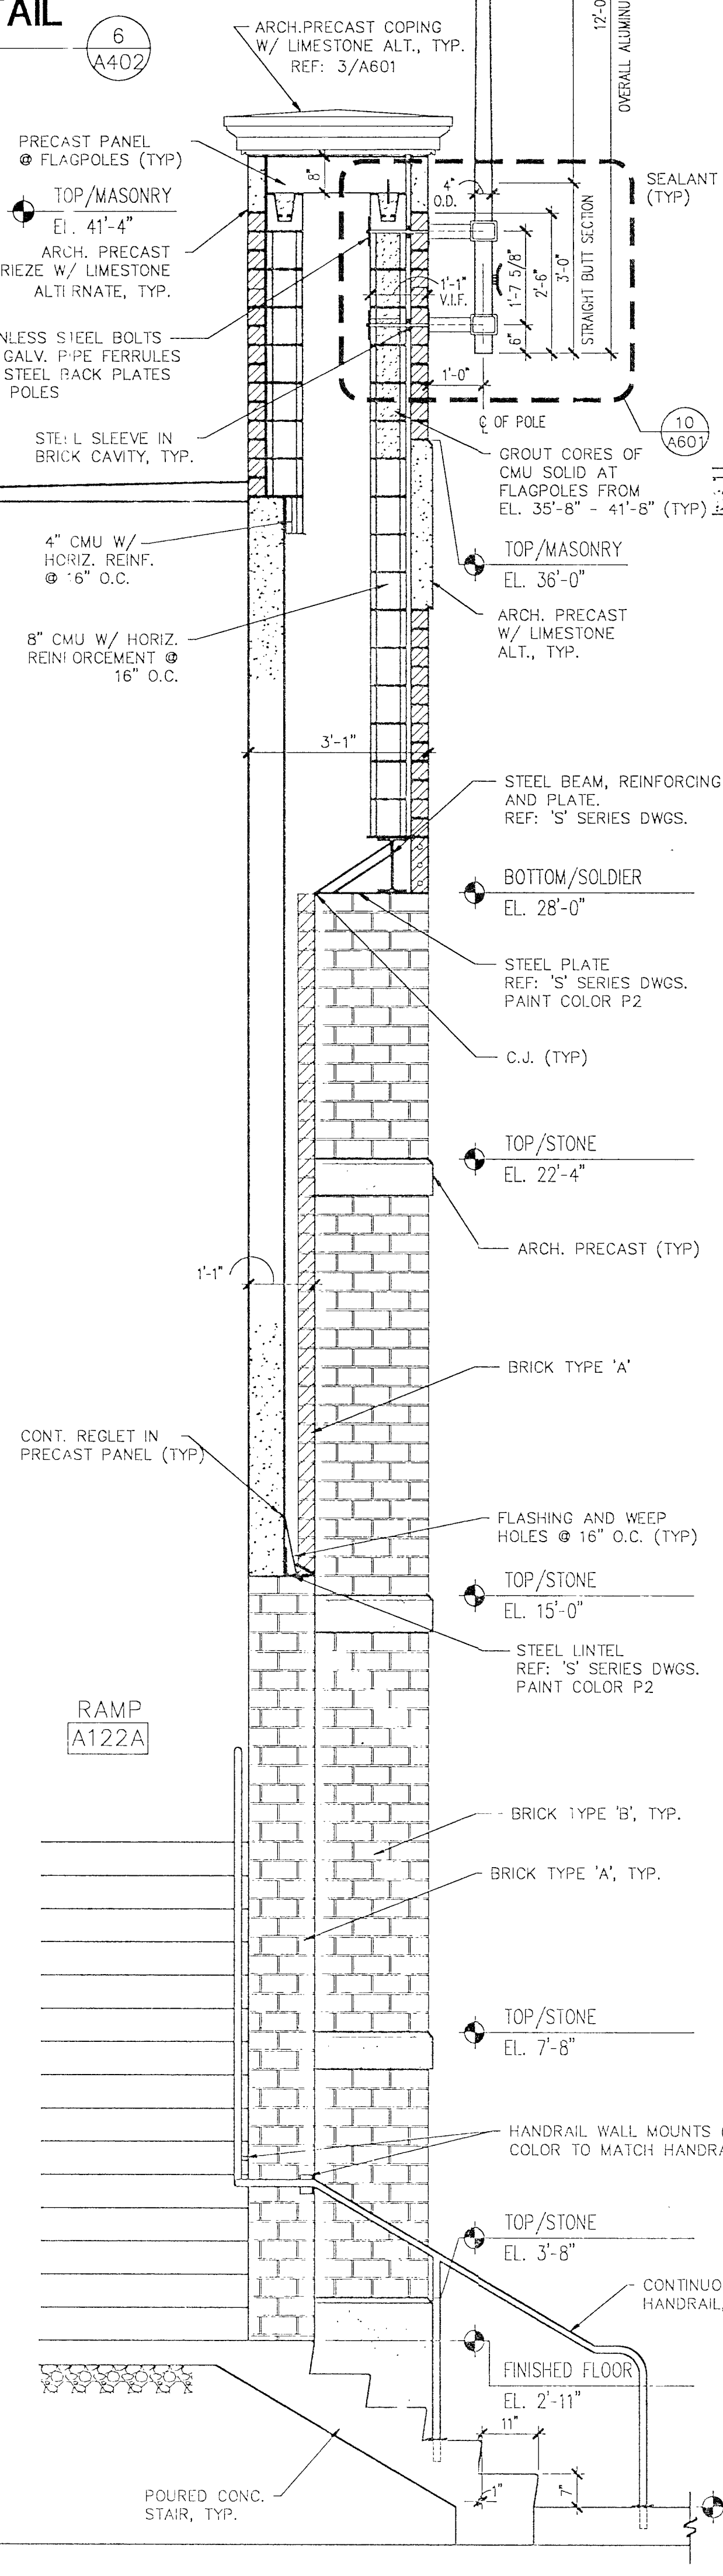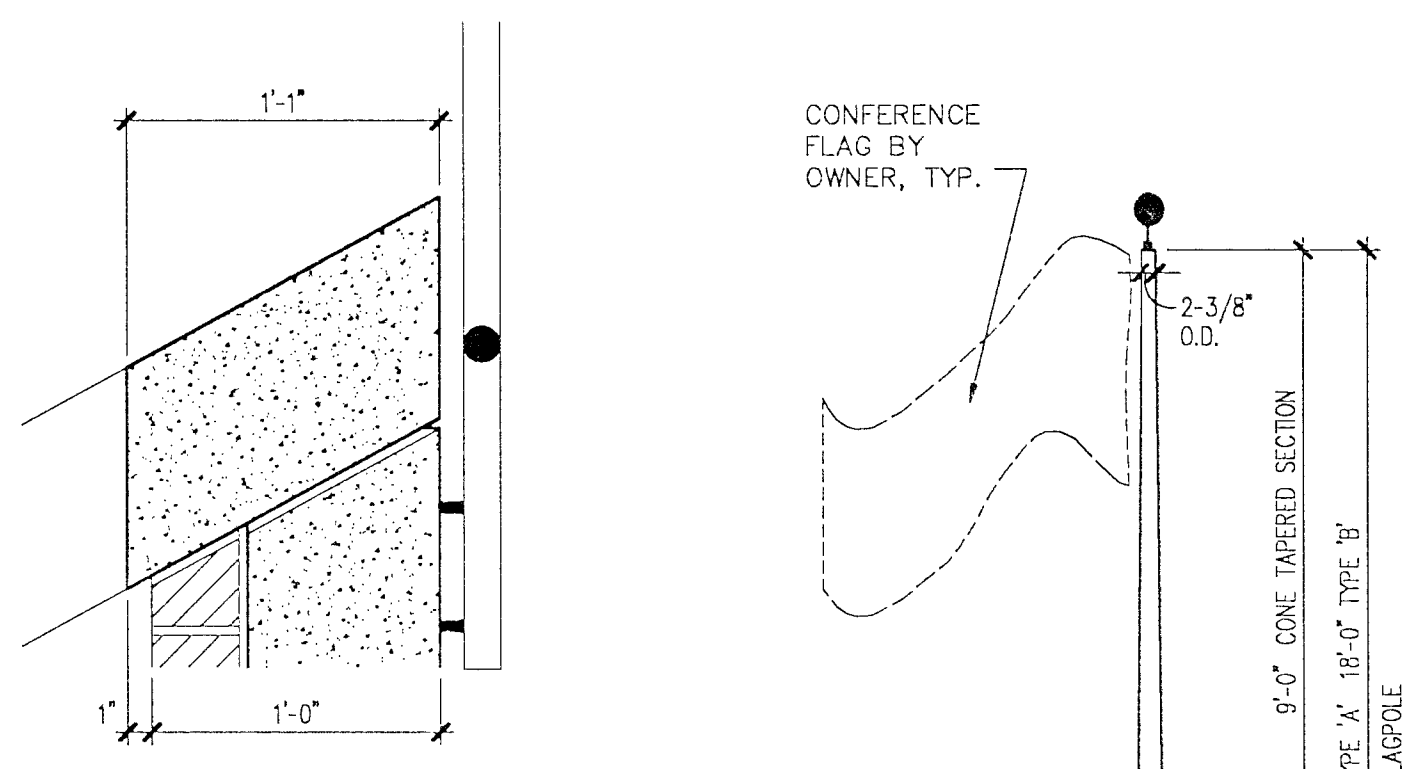


WALL SECTION FOOTBALL STADIUM

SCALE: 1/2"=1'-0"



WALL SECTION FOOTBALL STADIUM

SCALE: 1/2"=1'-0"

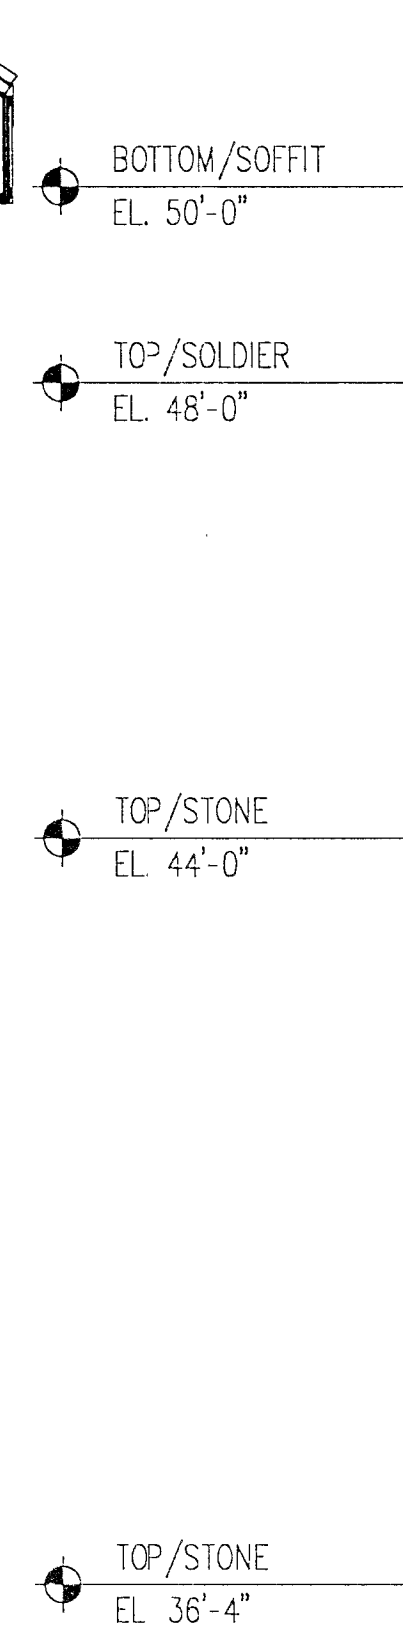



ARCH DETAIL

SCALE: 1" = 1'-0"

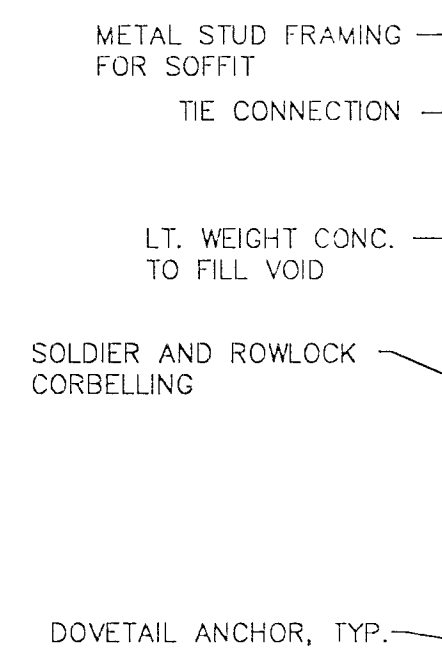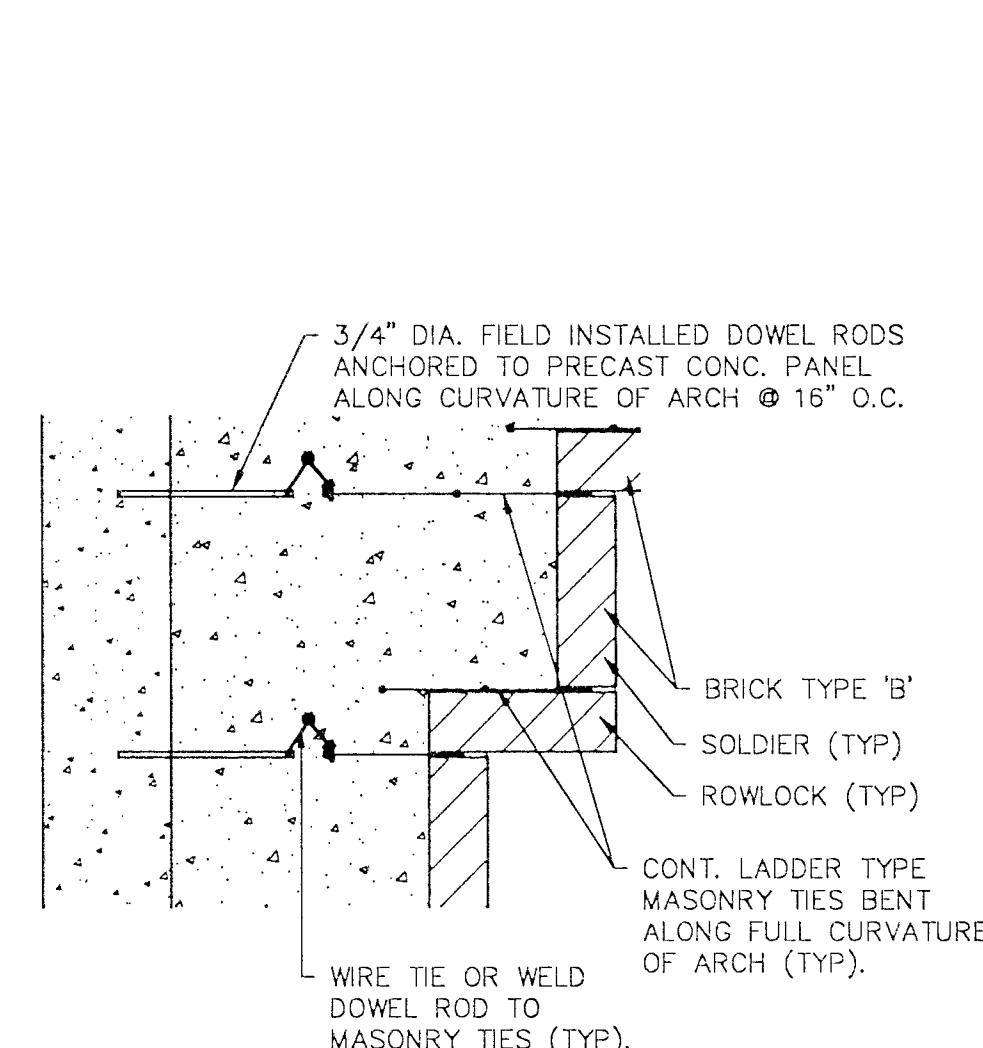

ARCH DETAIL

SCALE: 1-1/2"=1'-0"

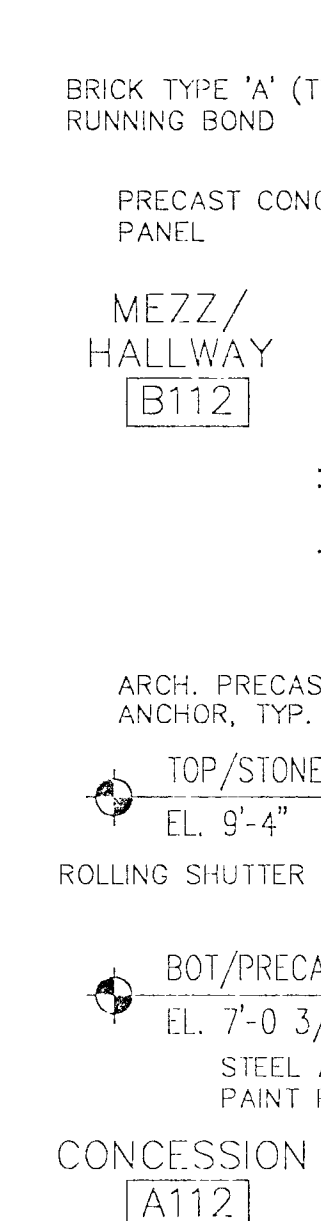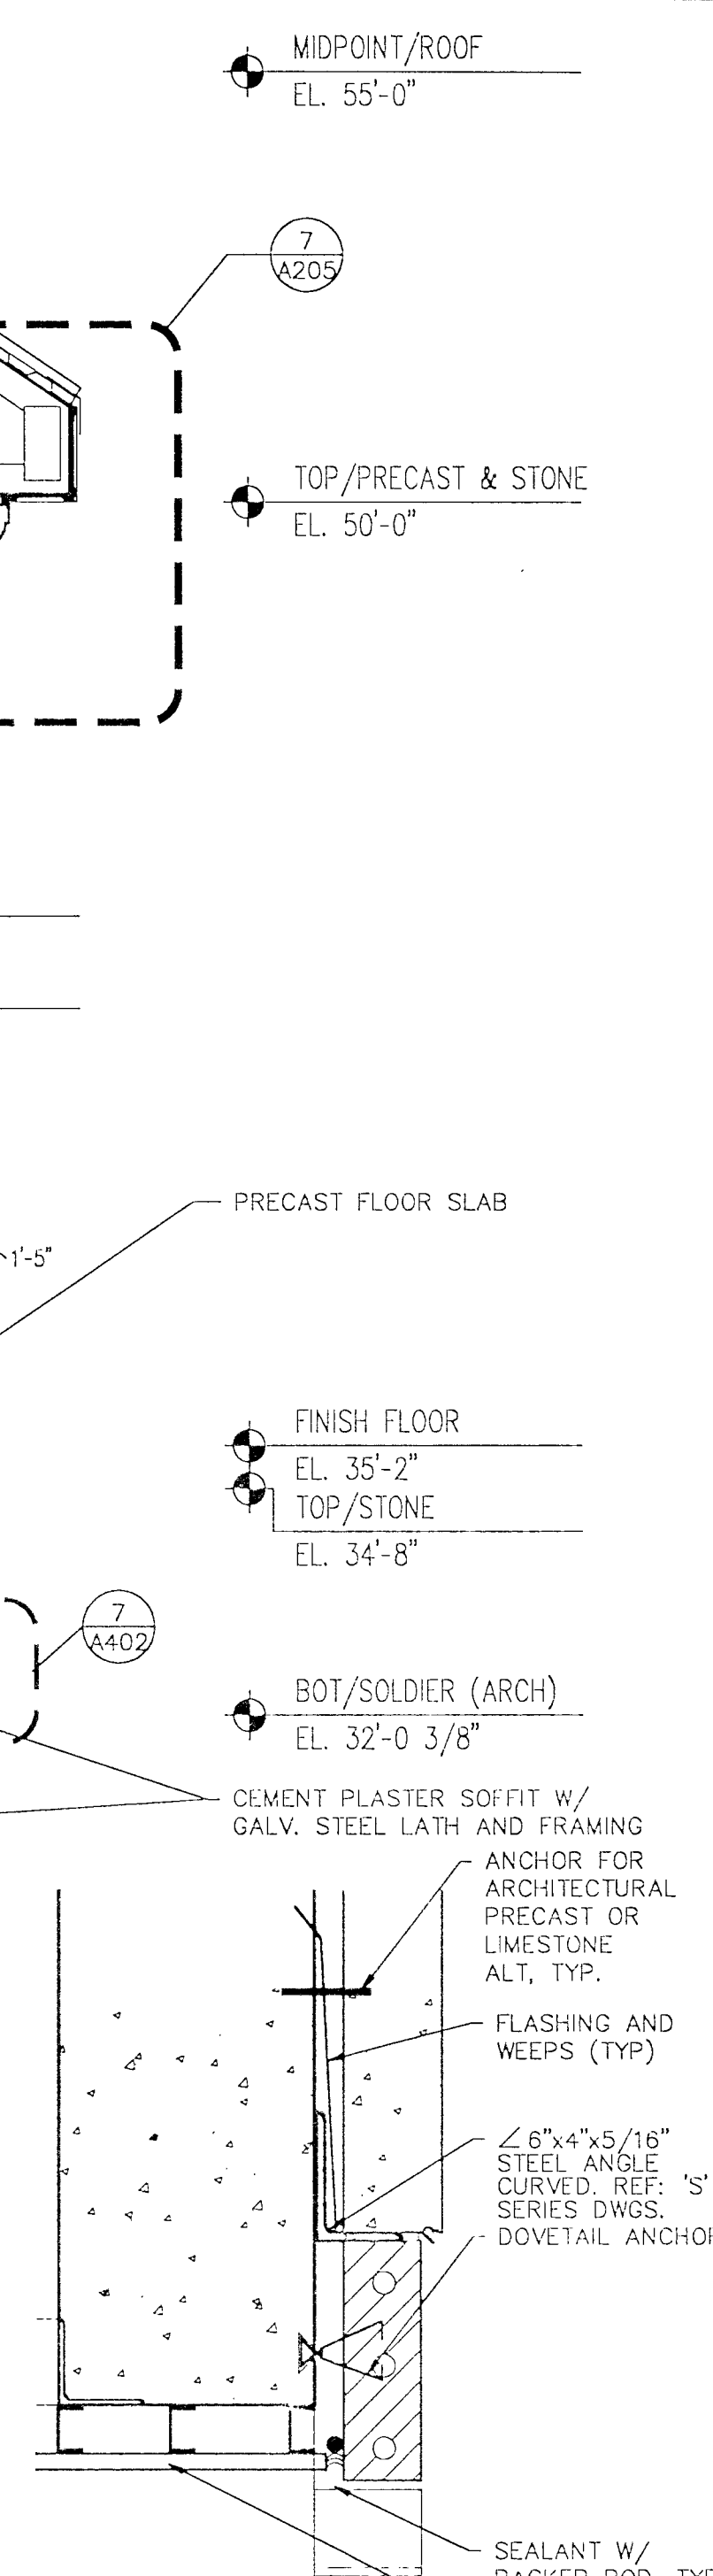

WALL SECTION FOOTBALL STADIUM ARCH

SCALE: 1/2"=1'-0"

NOTE: ALL REFERENCES TO STONE INDICATES ARCHITECTURAL PRECAST CONCRETE BASE BD. Limestone ALTERNATE.



THE ODL MCQUIRE & SHOOK CORPORATION
ARCHITECTURE • ENGINEERING • LANDSCAPE ARCHITECTURE • INTERIOR DESIGN
6785 NORTH STATE ROAD 37, POST OFFICE BOX 2149, BLOOMINGTON, INDIANA 47402, 812/876-2020
8275 ALISON POINTE TRAIL, POST OFFICE BOX 50428, INDIANAPOLIS, INDIANA 46250

REVISIONS


Copyright 1984 by THE ODL MCQUIRE & SHOOK CORPORATION. Copyright includes architectural work, building design, plans or drawings, and specifications. All structural work is the owner's responsibility as well as the engineer and contractor's responsibility. Reproduction without written permission is prohibited.

MICHIGAN CITY SPORTS COMPLEX
AMES FIELD
MICHIGAN CITY, INDIANA

PROJECT NO. 93052
DATE MAY 31, 1994
Drawn by: MRM
checked by: GJK

A402
WALL SECTIONS
FOOTBALL GRANDSTAND


F:\ARCHITECT\A403\A403 05-31-94 9:58:32

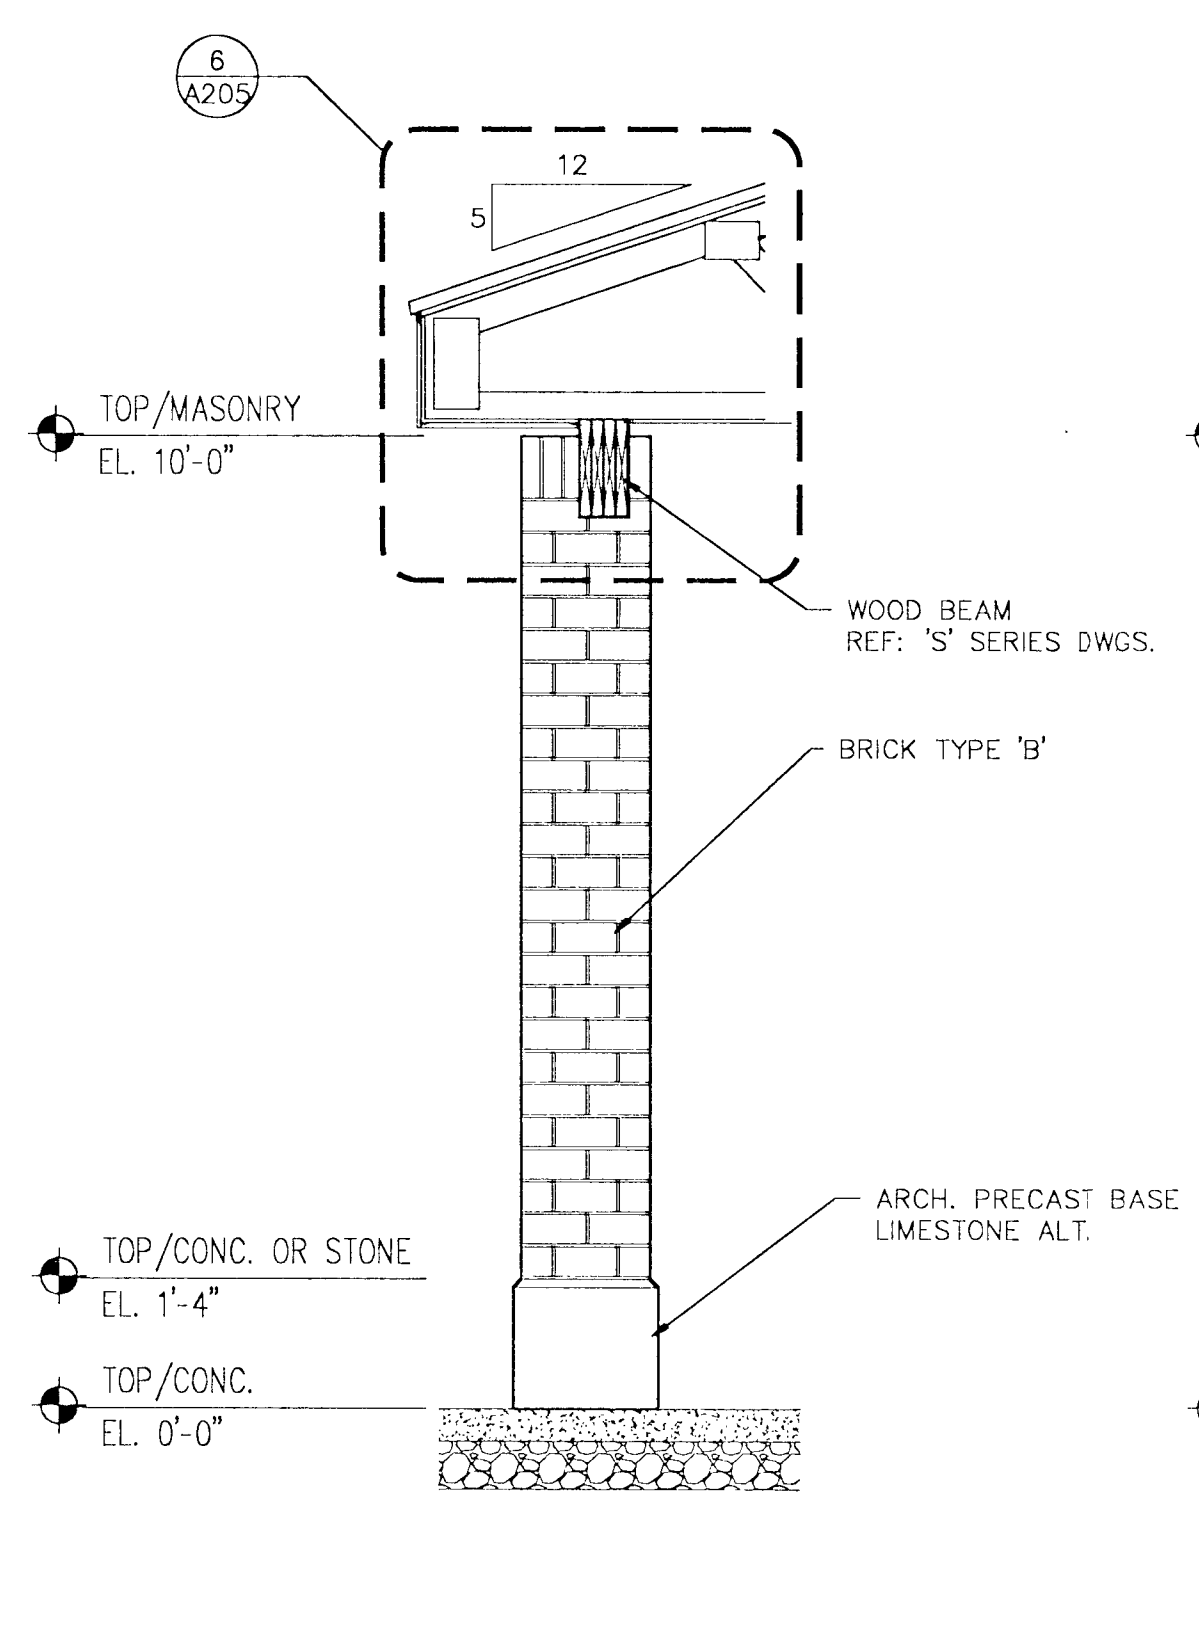

TYP. SECTION @ VISTOR TOILET & CONCESSION

SCALE: 1/2"=1'-0"


5
A403

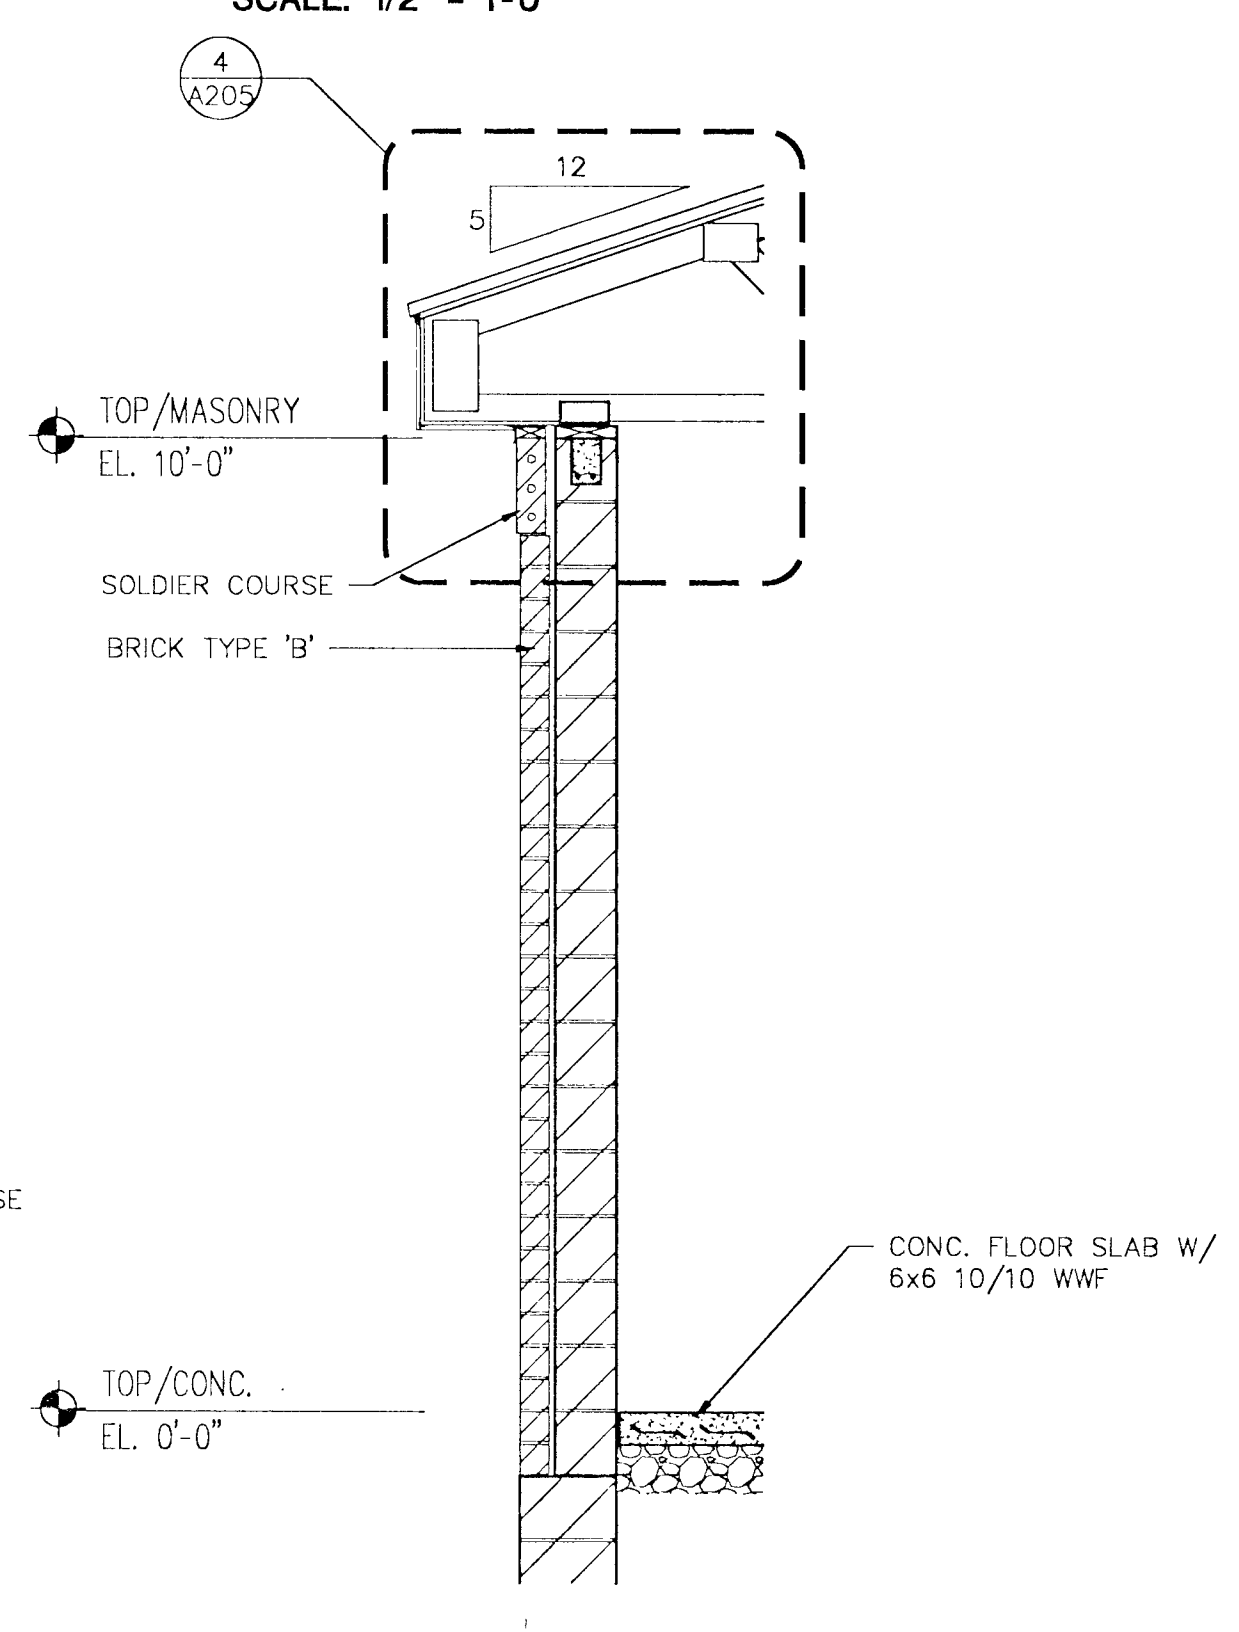

TYP. SECTION @ VISTOR TOILET & CONCESSION

SCALE: 1/2"=1'-0"


4
A403

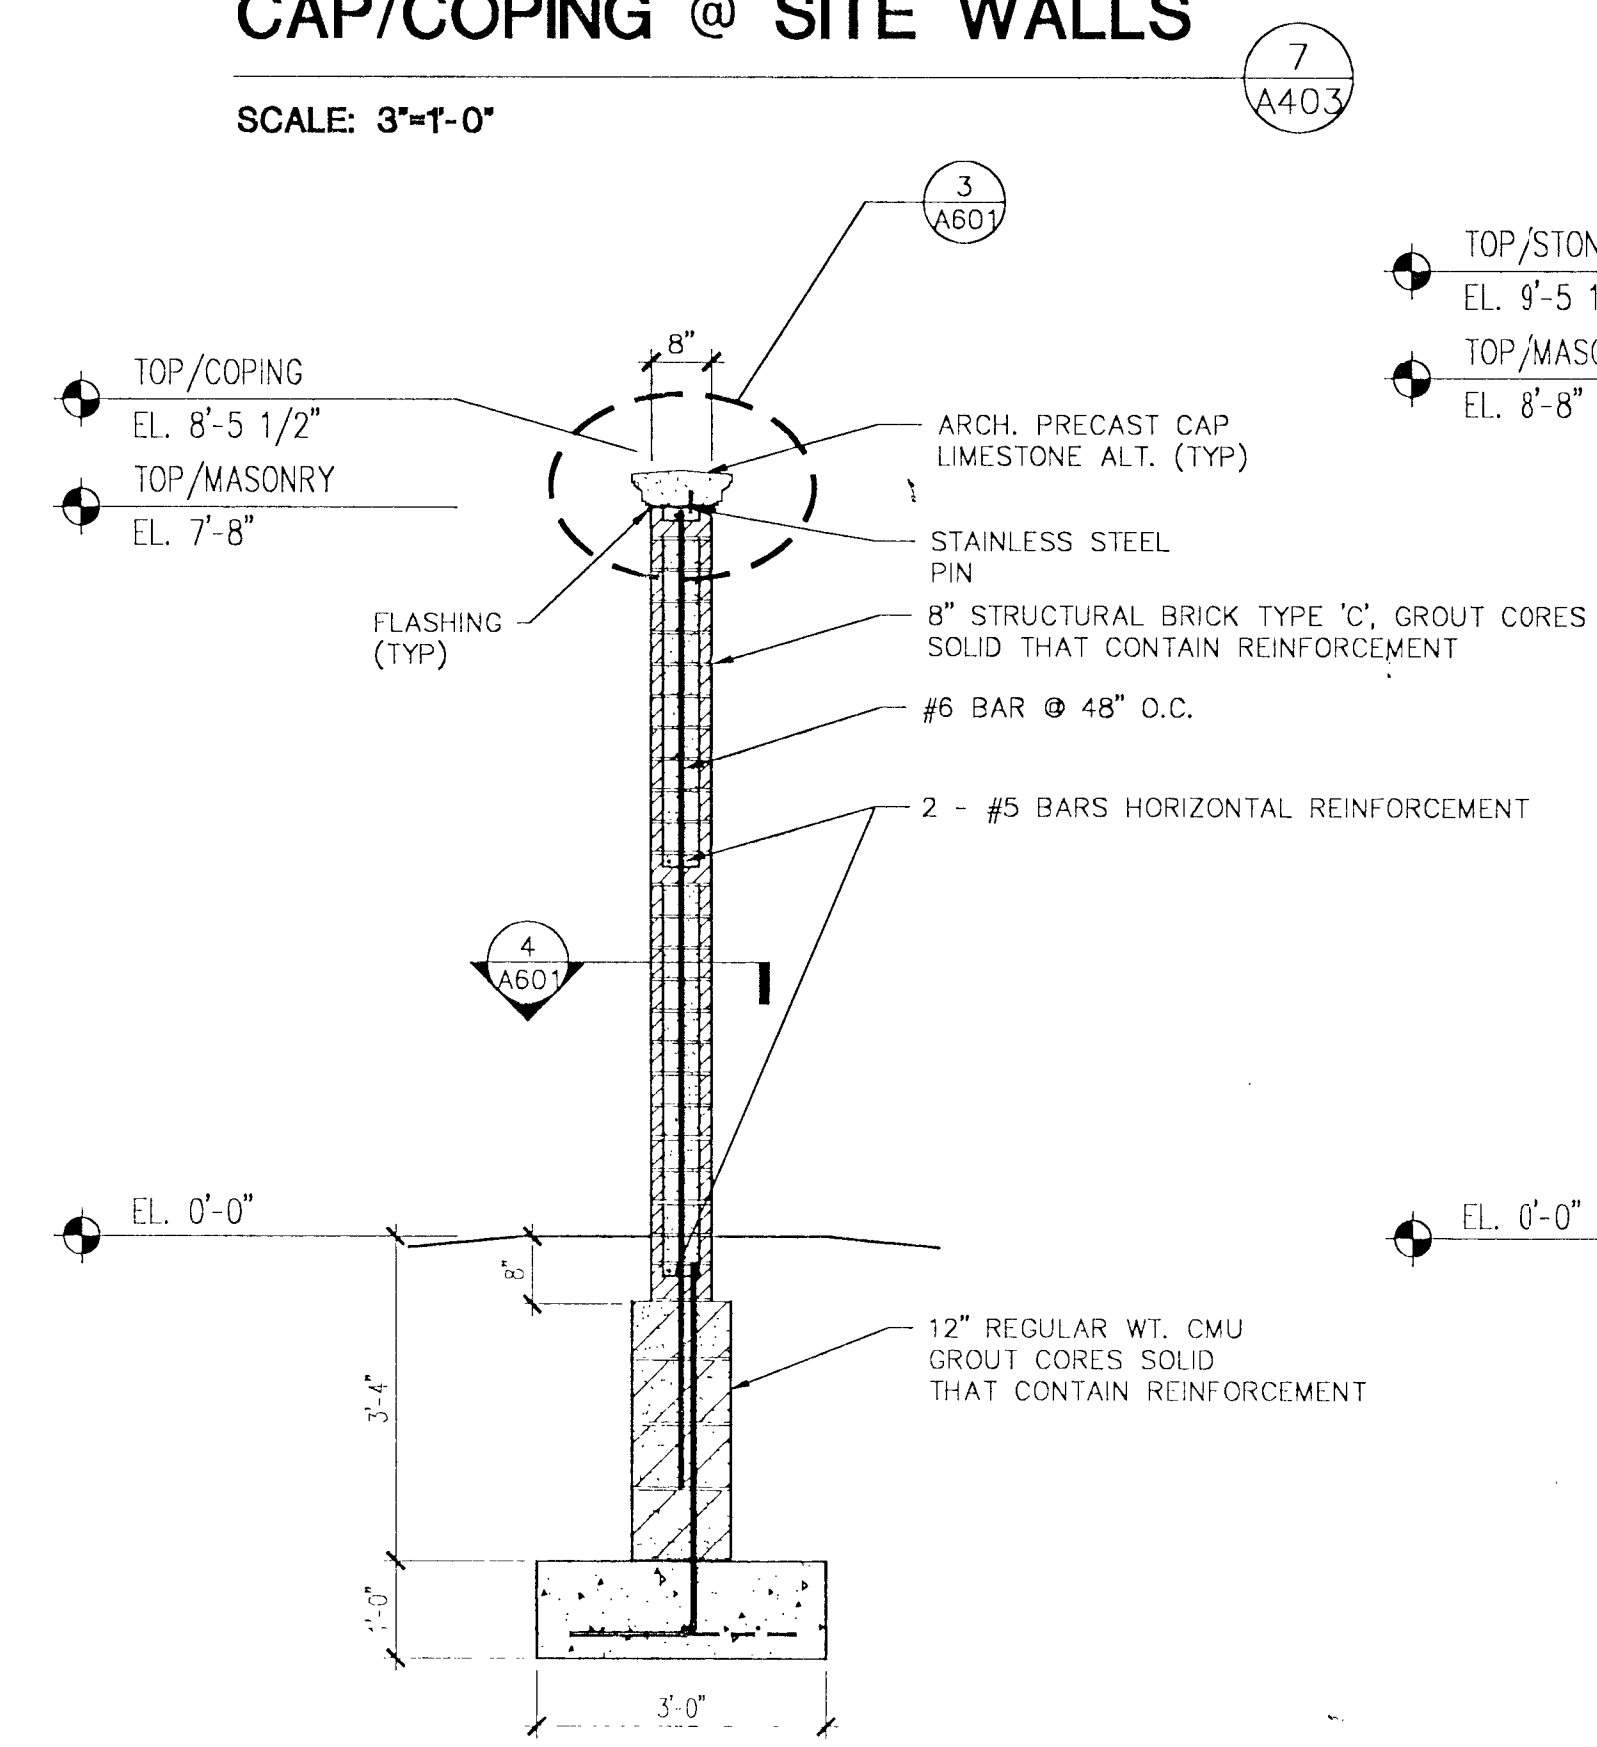

TYP. SECTION THROUGH SITE WALL

SCALE: 1/2"=1'-0"


3
A403

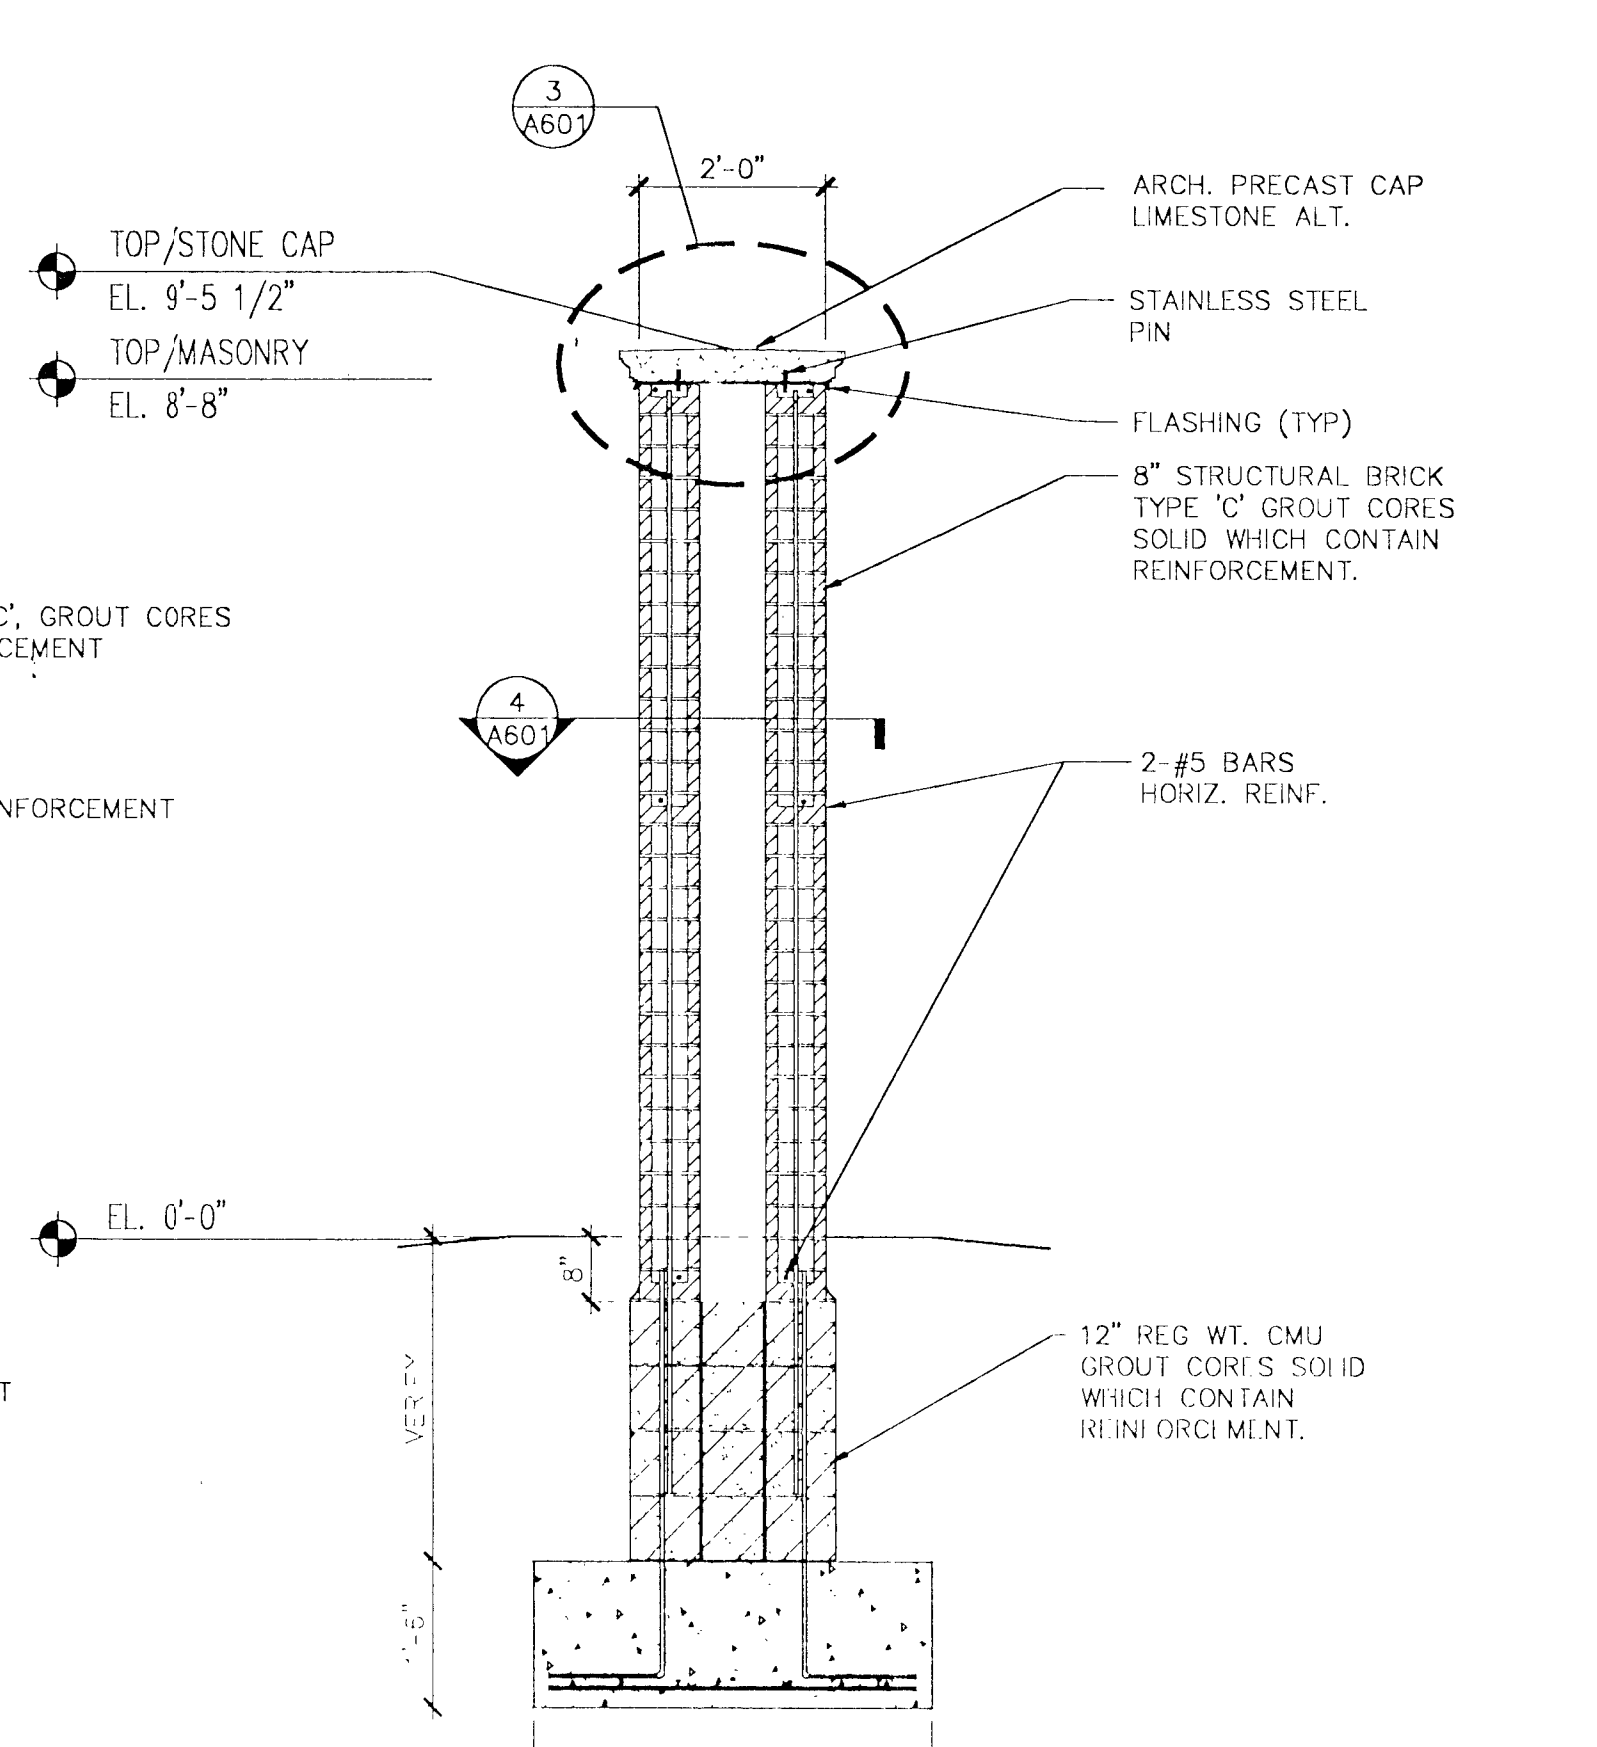

TYP. SECTION THROUGH PILASTER @ SITE WALL

SCALE: 1/2"=1'-0"


2
A403

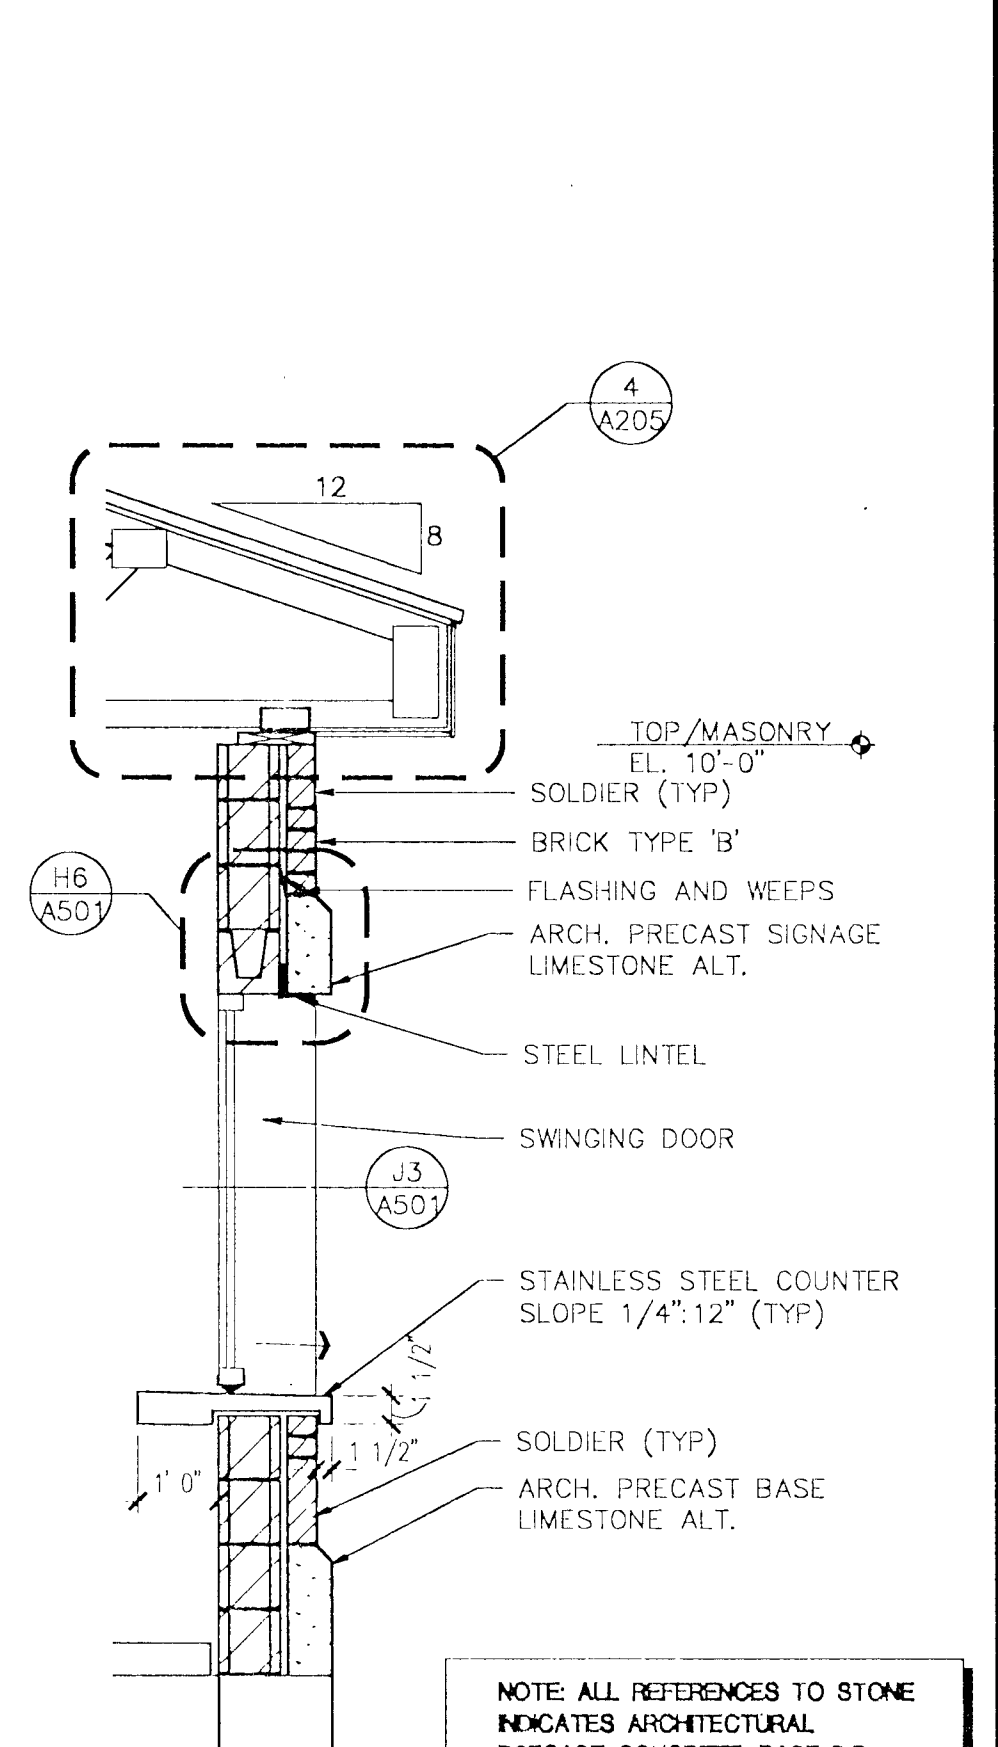

TYP. SECTION @ TICKET BOOTH

SCALE: 1/2"=1'-0"


1
A403

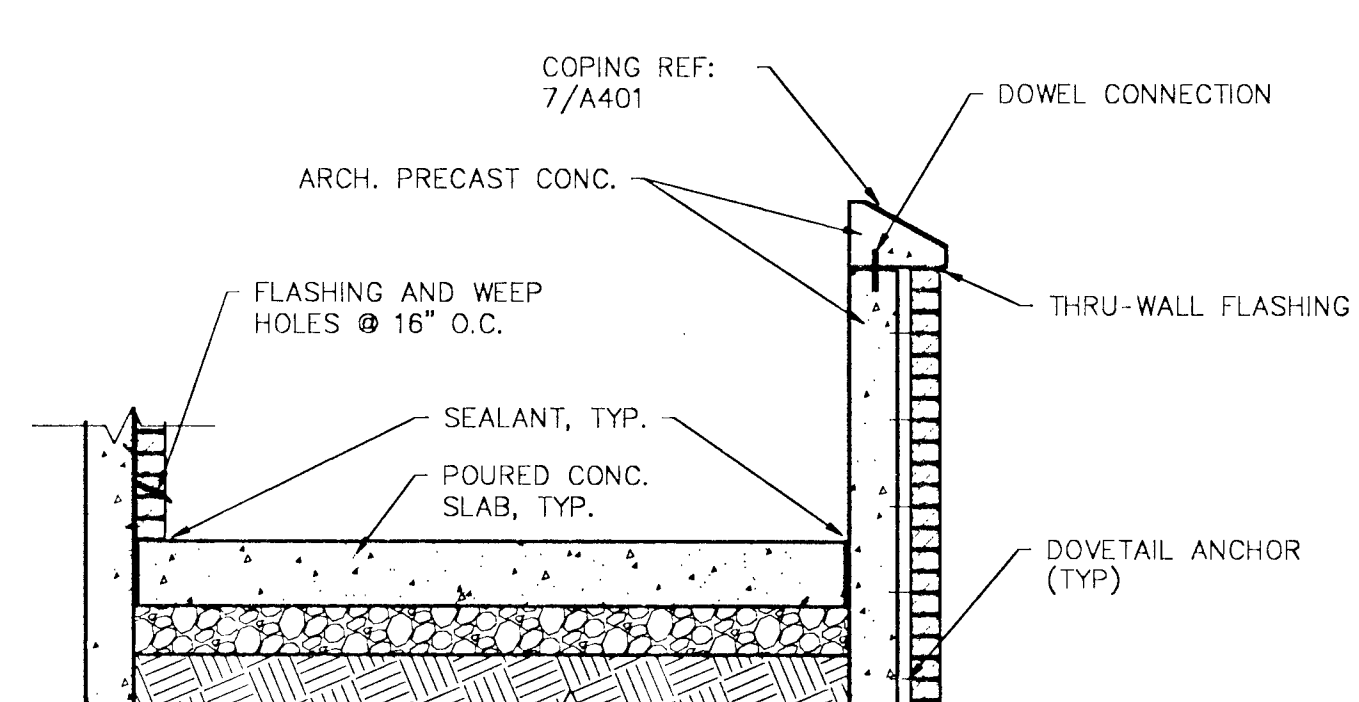

RAMP SECTION

SCALE: 1/2"=1'-0"


8
A403

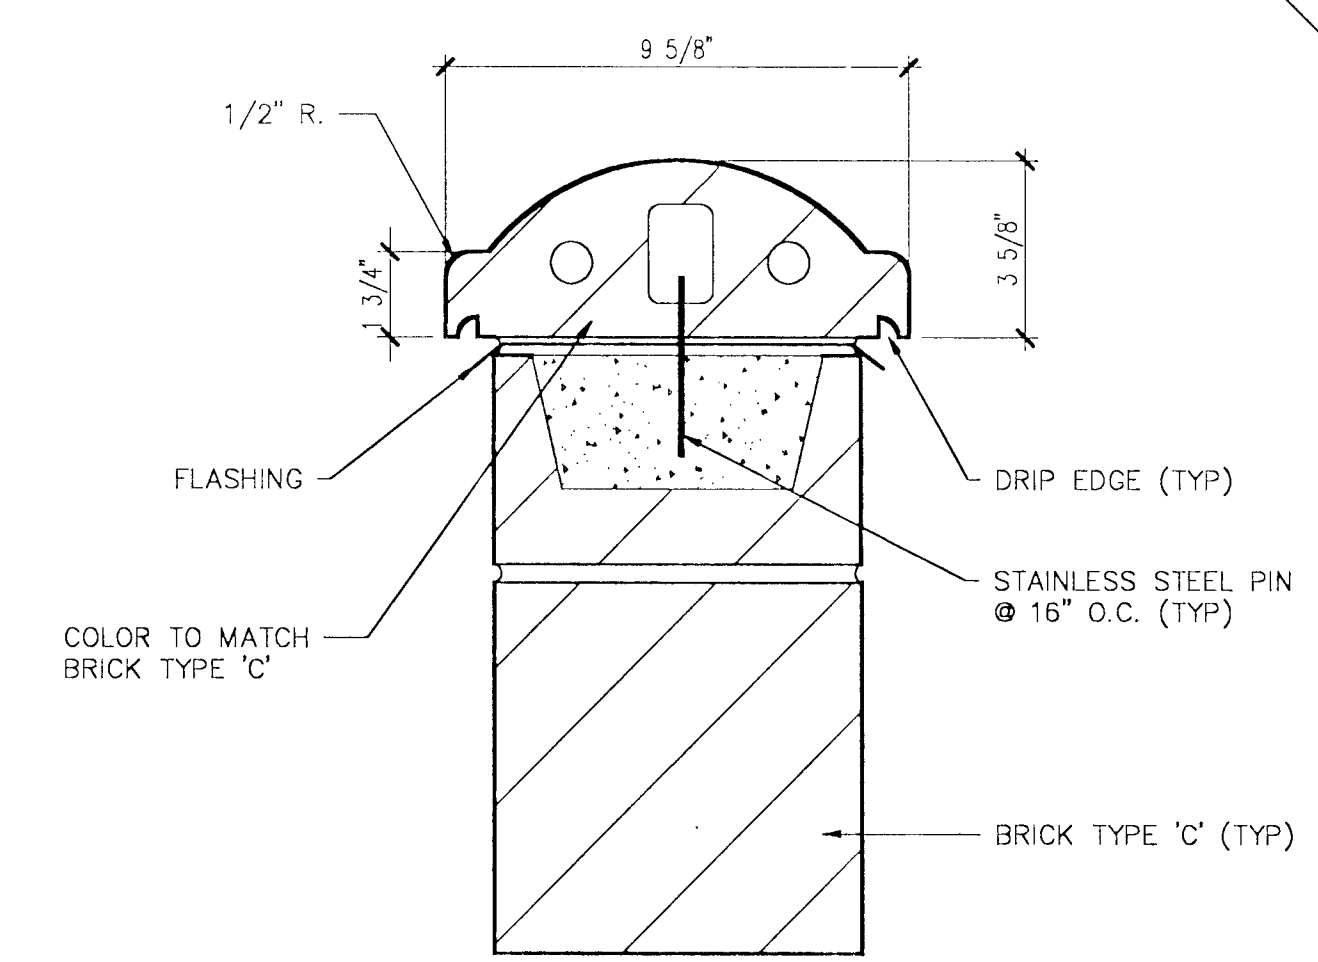

SECTION OF ALTERNATE BRICK CAP/COPING @ SITE WALLS

SCALE: 3"=1'-0"

7
A403

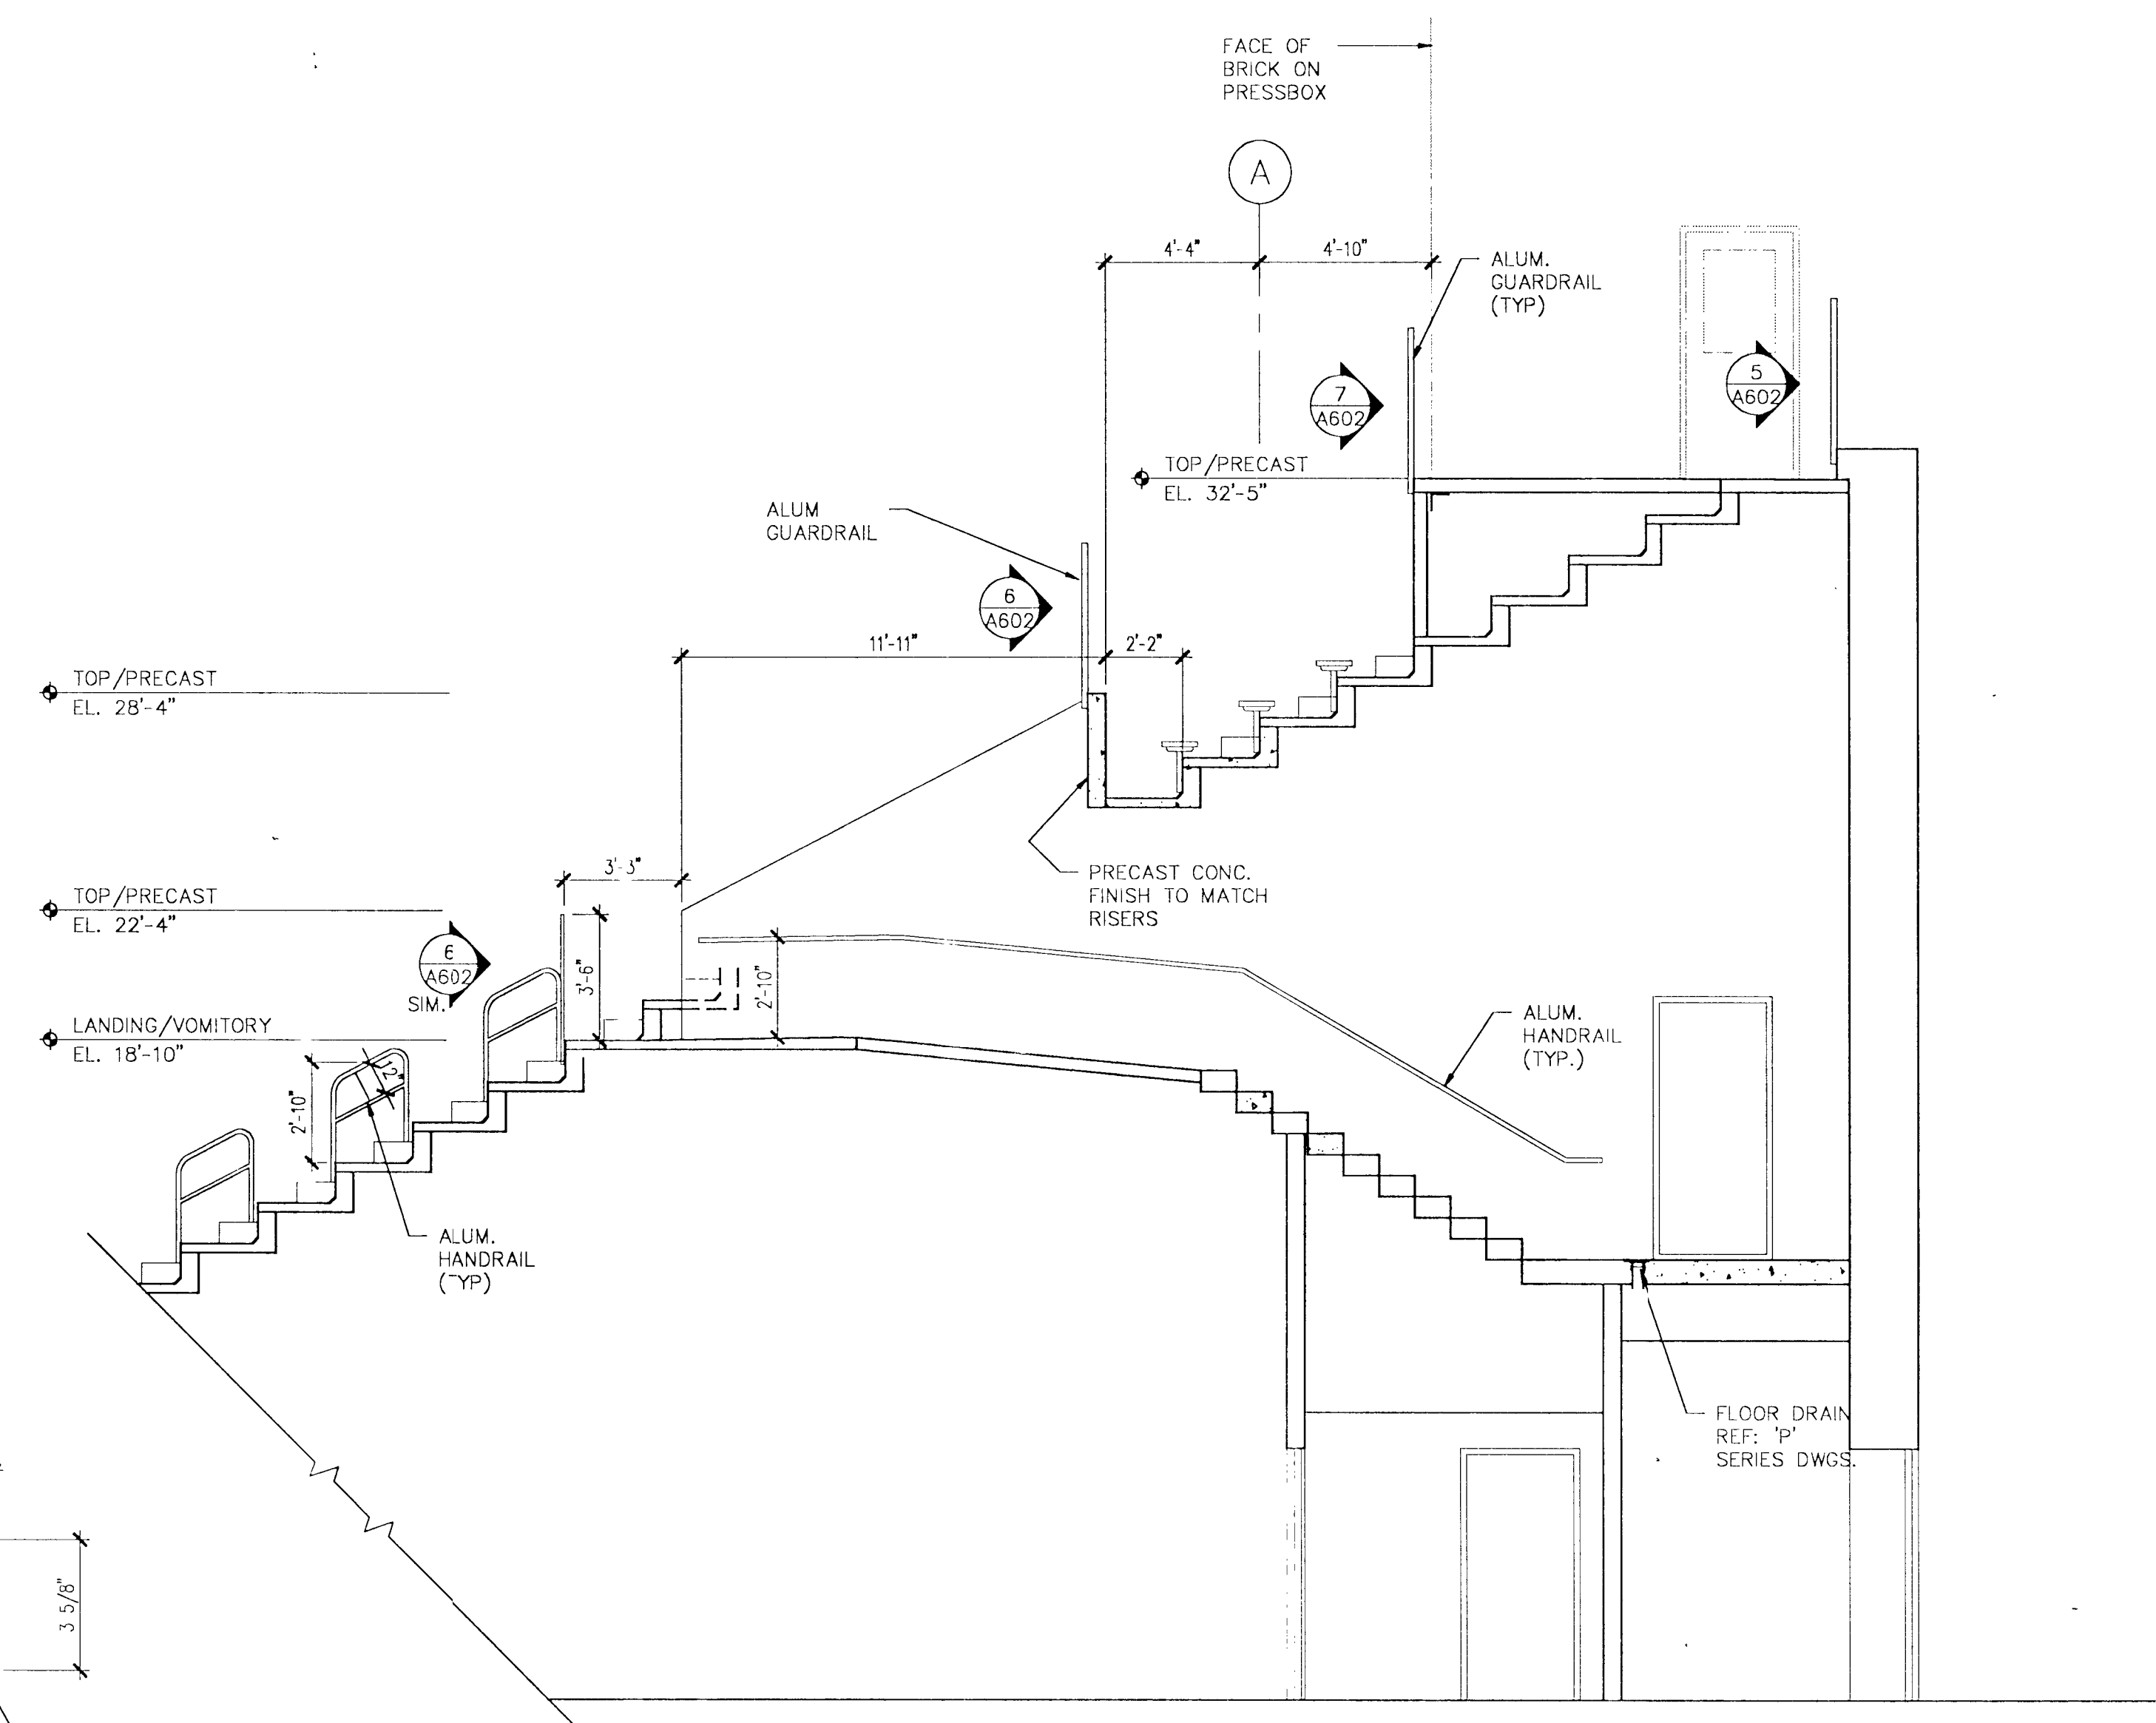

FOOTBALL GRANDSTAND SECTION

SCALE: 1/4"=1'-0"

6
A403



THE ODLE MCQUIRE & SHOOK CORPORATION
ARCHITECTURE • ENGINEERING • LANDSCAPE ARCHITECTURE • INTERIOR DESIGN
8785 WEST STATE ROAD 37, POST OFFICE BOX 2148, BLOOMINGTON, INDIANA 47403, 812/878-2000
8275 WILSON POINT ROAD, POST OFFICE BOX 50428, INDIANAPOLIS, INDIANA 46250, 317/848-0000

REVISIONS

© Copyright 1994 by THE ODLE MCQUIRE & SHOOK CORPORATION. Copyright includes architectural work, building design, plans or drawings, and specifications. Architectural work is the result of the design, planning, and construction of a project and is the property of THE ODLE MCQUIRE & SHOOK CORPORATION. Reproduction without written permission is prohibited.

MICHIGAN CITY SPORTS COMPLEX
AMES FIELD
MICHIGAN CITY, INDIANA


PROJECT NO. 93052
DATE MAY 31, 1994
drawn by: MRM/MCW
checked by: GKJ

A403
WALL SECTIONS
MISCELLANEOUS

DOOR AND FRAME SCHEDULE																	REMARKS	
OPENING NUMBER	DOOR				FRAME										LABEL	HARDWARE		REMARKS
	DOOR WIDTH	DOOR HEIGHT	DOOR THICKNESS	MATERIAL	ELEVATION	GLASS	PROFILE	MATERIAL	ELEVATION	GLASS	HEAD	JAMB	SILL					
FOOTBALL STADIUM																		
A101A	16'-0"	12'-0"	1"	STL	-	-	P3	STL	-	-	4/A402	J5	-	-	-	-	OHCOILING	
A101B	3'-0"	7'-0"	1-3/4"	STL	A	-	P1/P2	STL	1	-	H1	J1	-	-	-	B	-	
A102	3'-0"	7'-0"	1-3/4"	STL	A	-	P1/P2	STL	1	-	H2	J2	-	-	-	-	FRP. ALT.	
A103	3'-0"	7'-0"	1-3/4"	STL	A	-	P1/P2	STL	1	-	H1	J1	-	-	-	-	FRP. ALT.	
A104A (PR)	3'-0"	7'-0"	1-3/4"	STL	A	-	P1/P2	STL	2	-	H2	J2	-	-	-	-	FRP. ALT.	
A104B	NOT USED																	
A104C	3'-0"	7'-0"	1-3/4"	STL	A	-	P1/P2	STL	2	-	H1	J2	-	-	-	-	FRP. ALT.	
A104D	2'-2"	6'-0"	1-3/4"	STL	A	-	P1/P2	STL	1	-	H2	J2	-	-	-	-	FRP. ALT.	
A105A	3'-0"	7'-0"	1-3/4"	STL	A	-	P1/P2	STL	1	-	H1	J1	-	-	-	-	FRP. ALT.	
A105B	3'-0"	7'-0"	1-3/4"	STL	A	-	P1/P2	STL	1	-	H2	J2	-	-	-	-	FRP. ALT.	
A106	PR. 3'-0"	7'-0"	1-3/4"	STL	A	-	P1/P2	STL	2	-	H2	J2	-	-	-	-	FRP. ALT.	
A107A	3'-0"	7'-0"	1-3/4"	STL	A	-	P1/P2	STL	1	-	H2	J2	-	-	-	-	FRP. ALT.	
A107B	3'-0"	7'-0"	1-3/4"	STL	A	-	P1/P2	STL	1	-	H1	J1	-	-	-	-	FRP. ALT.	
A108A	3'-0"	7'-0"	1-3/4"	STL	A	-	P1/P2	STL	1	-	H2	J2	-	-	-	-	FRP. ALT.	
A108B	3'-0"	7'-0"	1-3/4"	STL	A	-	P1/P2	STL	1	-	H1	J1	-	-	-	-	FRP. ALT.	
A109A	3'-0"	7'-0"	1-3/4"	STL	A	-	P1/P2	STL	1	-	H4	J4	-	-	-	-	FRP. ALT.	
A109B	2'-4"	7'-0"	1-3/4"	STL	A	-	P1/P2	STL	1	-	H1	J1	-	-	-	-	FRP. ALT.	
A110A	3'-0"	7'-0"	1-3/4"	STL	A	-	P1/P2	STL	1	-	H4	J4	-	-	-	-	FRP. ALT.	
A110B	2'-4"	7'-0"	1-3/4"	STL	A	-	P1/P2	STL	1	-	H1	J1	-	-	-	-	FRP. ALT.	
A111	3'-0"	7'-0"	1-3/4"	STL	A	-	P1/P2	STL	1	-	H2	J2	-	-	-	-	-	
A112A	3'-0"	7'-0"	1-3/4"	STL	A	-	P1/P2	STL	1	-	H2	J2	-	-	-	-	-	
A112B	3'-0"	7'-0"	1-3/4"	STL	A	-	P1/P2	STL	1	-	H2	J2	-	-	-	-	-	
A113	3'-0"	7'-0"	1-3/4"	STL	A	-	P1/P2	STL	1	-	H4	J4	-	-	-	-	FRP. ALT.	
A114	3'-0"	7'-0"	1-3/4"	STL	A	-	P1/P2	STL	1	-	H2	J2	-	-	-	-	-	
A115A	3'-0"	7'-0"	1-3/4"	STL	A	-	P1/P2	STL	1	-	H1	J1	-	-	-	-	FRP. ALT.	
A115B	3'-0"	7'-0"	1-3/4"	STL	A	-	P1/P2	STL	1	-	H2	J2	-	-	-	-	FRP. ALT.	
A116 (PR)	3'-0"	7'-0"	1-3/4"	STL	A	-	P1/P2	STL	2	-	H2	J2	-	-	-	-	FRP. ALT.	
A117A	3'-0"	7'-0"	1-3/4"	STL	A	-	P1/P2	STL	2	-	H2	J2	-	-	-	-	FRP. ALT.	
A117B	NOT USED																	
A117C	3'-0"	7'-0"	1-3/4"	STL	A	-	P1/P2	STL	1	-	H1	J1/J2	-	-	-	-	FRP. ALT.	
A117D	2'-2"	6'-0"	1-3/4"	STL	A	-	P1/P2	STL	1	-	H2	J2	-	-	-	-	FRP. ALT.	
A118A	3'-0"	7'-0"	1-3/4"	STL	A	-	P1/P2	STL	1	-	H1	J1	-	-	-	-	FRP. ALT.	
A118B	3'-0"	7'-0"	1-3/4"	STL	A	-	P1/P2	STL	1	-	H1	J1	-	-	-	-	FRP. ALT.	
A119A	16'-0"	12'-0"	1"	STL	OH	-	P3	STL	-	-	4/A402	J5	-	-	-	-	OHCOILING	
A119B	3'-0"	7'-0"	1-3/4"	STL	A	-	P1/P2	STL	1	-	H1	J1	-	-	-	B	-	
A120	NOT USED																	
A121	3'-0"	7'-0"	1-3/4"	STL	A	-	P1/P2	STL	1	-	H1	J1	-	-	-	B	-	
A122	3'-0"	7'-0"	1-3/4"	STL	A	-	P1/P2	STL	1	-	H2	J2	-	-	-	-	FRP. ALT.	
B112	3'-0"	7'-0"	1-3/4"	STL	A	-	P1/P2	STL	1	-	H2	J2	-	-	-	B	-	
FOOTBALL STADIUM PRESSBOX																		
A123A	3'-0"	7'-0"	1-3/4"	STL	B	-	P1/P2	STL	1	-	H4	J4	-	-	-	-	FRP. ALT.	
A123B	3'-0"	7'-0"	1-3/4"	STL	B	-	P1/P2	STL	1	-	H4	J4	-	-	-	-	FRP. ALT.	
A123C	2'-6"	7'-0"	1-3/4"	STL	A	-	P1/P2	STL	1	-	H1	J1/J2	-	-	-	-	FRP. ALT.	
A124	3'-0"	7'-0"	1-3/4"	STL	A	-	P1/P2	STL	1	-	H1	J1	-	-	-	-	FRP. ALT.	
A125	3'-0"	7'-0"	1-3/4"	STL	A	-	P1/P2	STL	1	-	H1	J1	-	-	-	-	FRP. ALT.	
A126	3'-0"	7'-0"	1-3/4"	STL	A	-	P1/P2	STL	1	-	H1	J1	-	-	-	-	FRP. ALT.	
A127	3'-0"	7'-0"	1-3/4"	STL	A	-	P1/P2	STL	1	-	H1	J1	-	-	-	-	FRP. ALT.	
VISITOR TOILET & CONCESSION																		
B101A	3'-0"	7'-0"	1-3/4"	STL	A	-	P1/P2	STL	1	-	H3	J3	-	-	-	-	FRP. ALT.	
B101B	3'-0"	7'-0"	1-3/4"	STL	A	-	P1/P2	STL	1	-	H1	J1	-	-	-	-	FRP. ALT.	
B101C	PR. 1'-10"	2'-8"	1-3/4"	STL	A	-	P1/P2	STL	1	-	H6	J3	-	-	-	-	FRP. ALT.	
B101D	PR. 1'-10"	2'-8"	1-3/4"	STL	A	-	P1/P2	STL	1	-	H6	J3	-	-	-	-	FRP. ALT.	
B102A	3'-0"	7'-0"	1-3/4"	STL	A	-	P1/P2	STL	1	-	H5	J3	-	-	-	-	FRP. ALT.	
B102B	2'-2"	7'-0"	1-3/4"	STL	A	-	P1/P2	STL	1	-	H1	J1	-	-	-	-	FRP. ALT.	
B103A	2'-2"	7'-0"	1-3/4"	STL	A	-	P1/P2	STL	1	-	H1	J1	-	-	-	-	FRP. ALT.	
B103B	2'-2"	7'-0"	1-3/4"	STL	A	-	P1/P2	STL	1	-	H1	J1	-	-	-	-	FRP. ALT.	
B104 (PR)	3'-0"	7'-0"	1-3/4"	STL	A	-	P1/P2	STL	2	-	H3	J3	-	-	-	-	FRP. ALT.	
B105	3'-0"	7'-0"	1-3/4"	STL	A	-	P1/P2	STL	1	-	H5	J3	-	-	-	-	FRP. ALT.	
TICKET BOOTHS																		
C101A	3'-0"	7'-0"	1-3/4"	STL	A	-	P1/P2	STL	1	-	H3	J3	-	-	-	-	FRP. ALT.	
C101B	1'-8"	3'-8"	1-3/4"	STL	A	-	P1/P2	STL	1	-	H6	J3	-	-	-	-	FRP. ALT.	
C101C	1'-8"	3'-8"	1-3/4"	STL	A	-	P1/P2	STL	1	-	H6	J3	-	-	-	-	FRP. ALT.	
C102A	3'-0"	7'-0"	1-3/4"	STL	A	-	P1/P2	STL	1	-	H3	J3	-	-	-	-	FRP. ALT.	
C102B	1'-8"	3'-8"	1-3/4"	STL	A	-	P1/P2	STL	1	-	H6	J3	-	-	-	-	FRP. ALT.	
C102C	1'-8"	3'-8"	1-3/4"	STL	A	-	P1/P2	STL	1	-	H6	J3	-	-	-	-	FRP. ALT.	

LINTEL SCHEDULE

- WHERE LINTELS ARE SHOWN ON DRAWINGS BUT NOT NOTED; WHERE OPENINGS NOT SHOWN ARE CUT THRU MASONRY CONSTRUCTION AND REQUIRE LINTELS, AND WHERE LINTELS ARE NOT SHOWN OR NOTED ON DRAWINGS, THE FOLLOWING SHALL COVER FOR ALL OPENINGS.
- STEEL LINTELS WITH OPENINGS UP TO 4'-0" SHALL HAVE 1" OF BEARING FOR EACH FOOT OF SPAN, BUT IN NO CASE SHALL THE BEARING BE LESS THAN 6".
- FOR OPENINGS UP TO 4'-0" PROVIDE (1) 3-1/2" X 3-1/2" X 5/16" ANGLE FOR EACH 4" THICKNESS OF WALL, WHERE MORE THAN 2 ANGLES ARE PROVIDED AND ARE NOT CONCEALED; PROVIDE 1/4" STEEL PLATE WELDED TO BOTTOM OF ANGLES WHERE EXPOSED.
- FOR OPENINGS GREATER THAN 4'-0" AND LESS THAN 8'-0" PROVIDE (1) 6" X 3-1/2" X 3/8" ANGLE FOR EACH 4" THICKNESS OF WALL, WHERE MORE THAN 2 ANGLES ARE PROVIDED AND ARE NOT CONCEALED; PROVIDE 1/4" STEEL PLATE WELDED TO BOTTOM OF ANGLES WHERE EXPOSED.
- PROVIDE 75'-0" OF EACH ANGLE SIZE ABOVE FOR USE AS DIRECTED BY ARCHITECT/ENGINEER.
- PRECAST CONCRETE LINTELS SHALL HAVE 8" OF BEARING AND BE REINFORCED AS FOLLOWS UP TO 8'-4" SPAN 4" TO 6" WIDE - (1) #4 BAR TOP AND BOTTOM 8" TO 10" WIDE - (2) #5 BARS TOP AND BOTTOM 12" TO 14" WIDE - (2) #5 BARS TOP AND BOTTOM
- C.M.U. LINTELS SHALL BE CONC. BOND BEAMS FOR SPANS UP TO 8'-0". BOND BEAMS SHALL HAVE 8" OF BEARING AND BE REINFORCED WITH 2 - #5 BARS.
- FOR SPANS GREATER THAN 8'-0", A STEEL BEAM IS REQUIRED. REF: STRUCTURAL PLANS FOR STEEL BEAM SIZE.

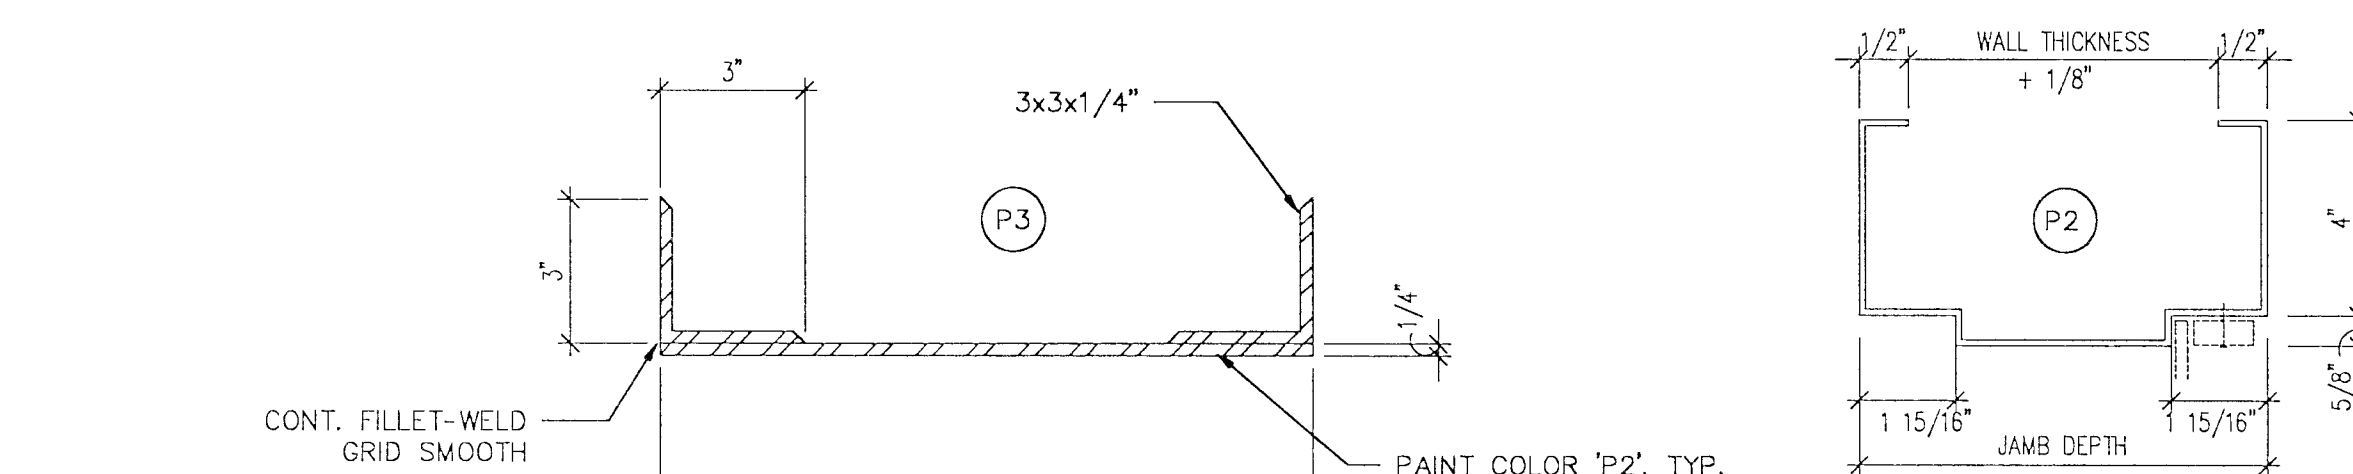


FRAME PROFILE

SCALE: 3\"/>

HOLLOW METAL FRAME PROFILES

SCALE: 3\"/>

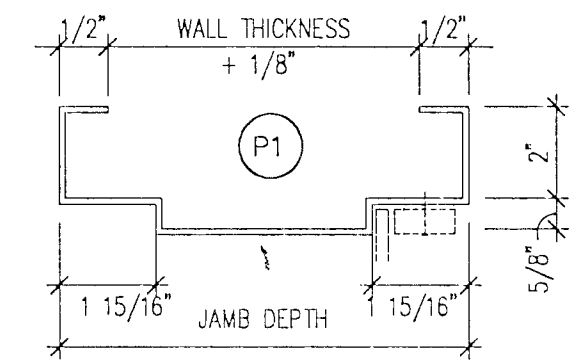

DOOR FRAME ELEV.


SCALE: 1/4\"/>

NOTE: ALL DOOR FRAMES COLOR EP-2 UNO.


DOOR ELEVATIONS

SCALE: 1/4\"/>


NOTE: ALL DOOR FRAMES COLOR EP-2 UNO.

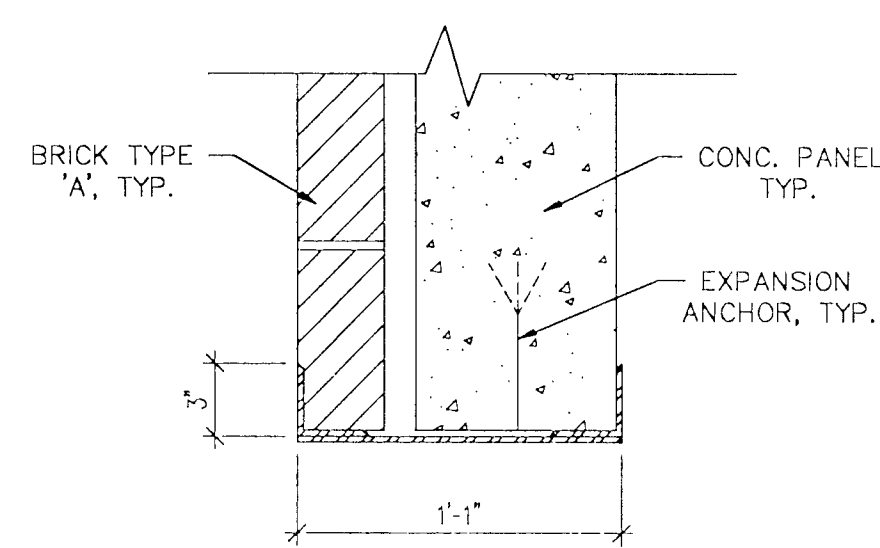


J5

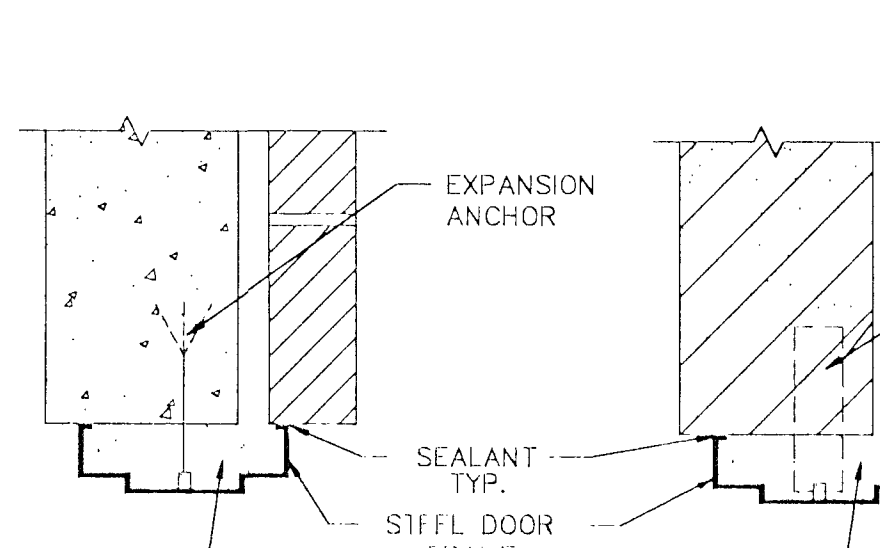


J4

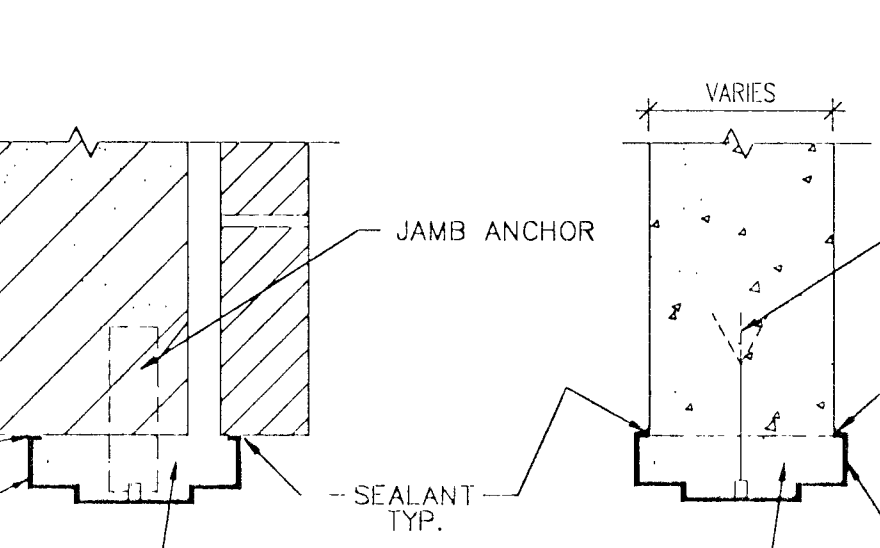


J5

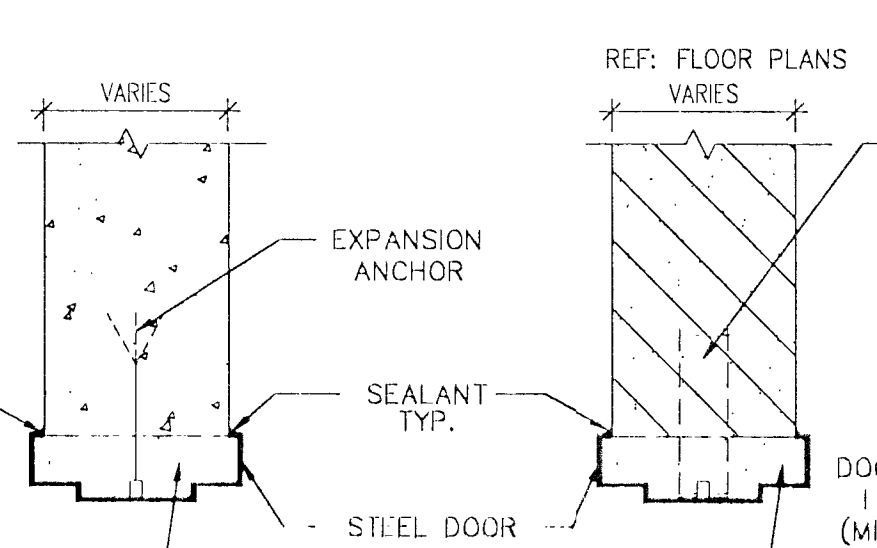


J2

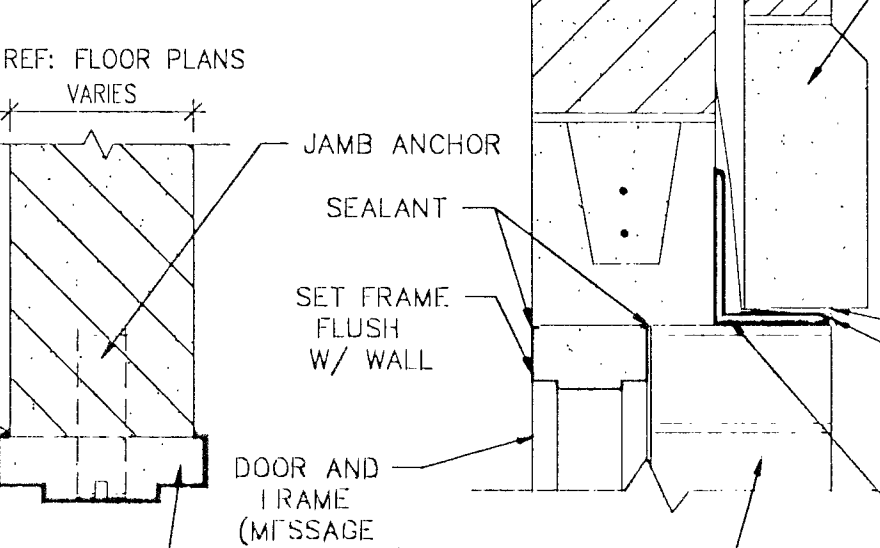


J1

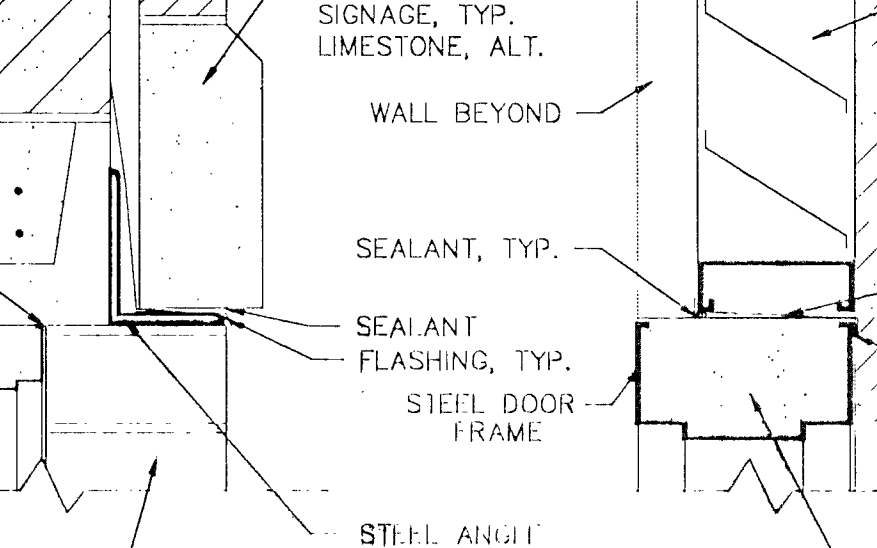


J6

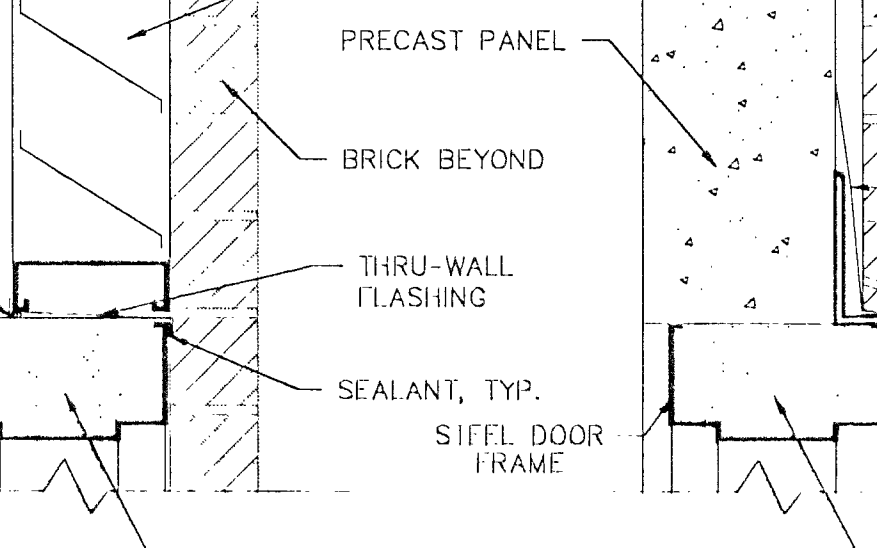


J7

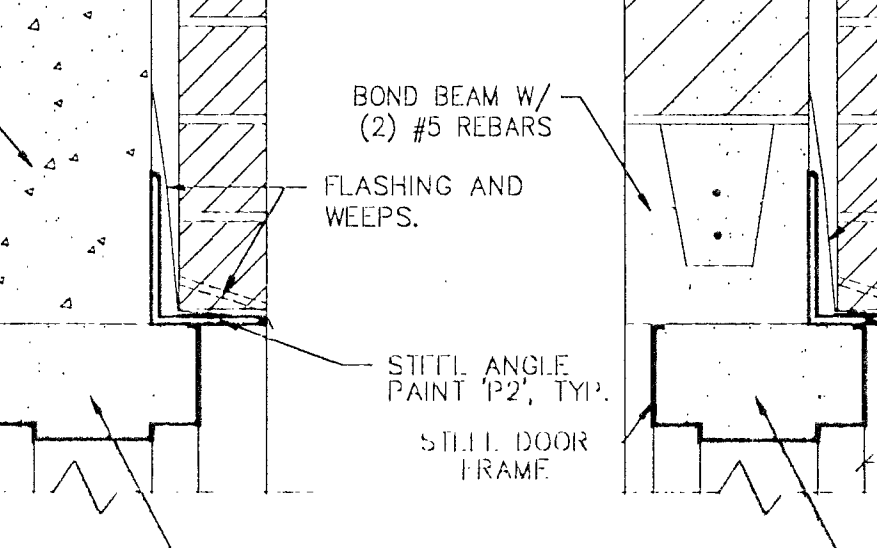


J4

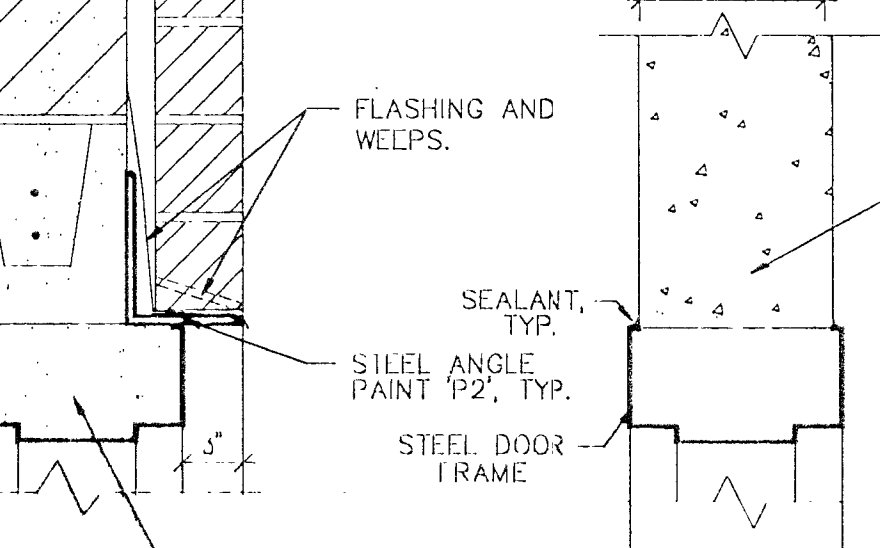

J5

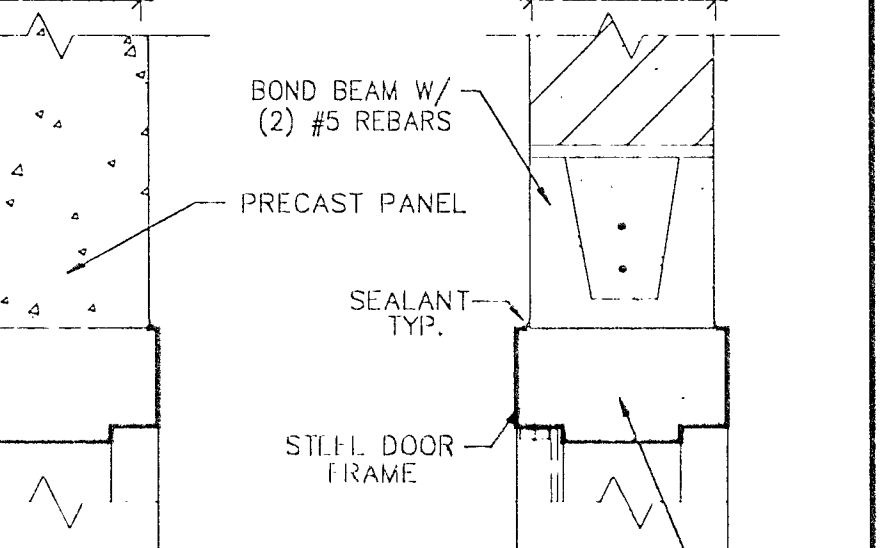


J2

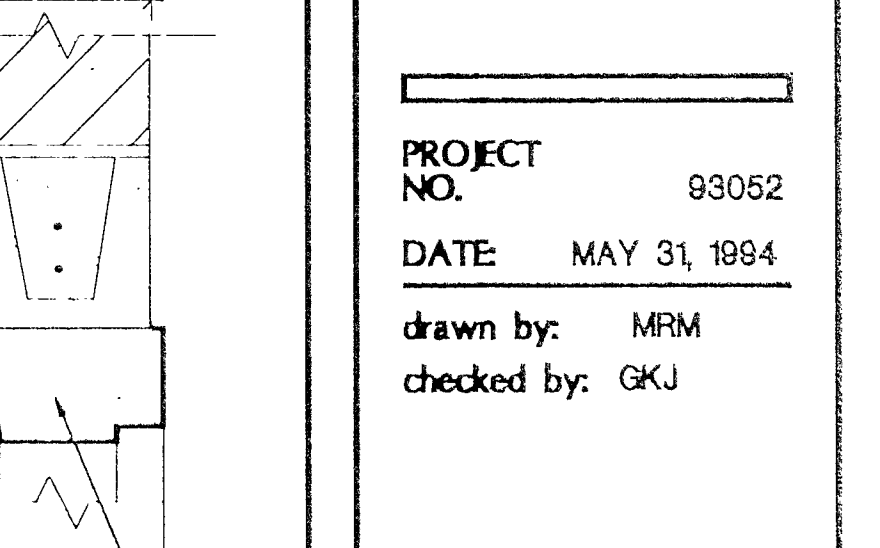


J1


FINISH SCHEDULE																
RM. NO.	ROOM NAME	FLOOR		BASE	NORTH WALL		SOUTH WALL		EAST WALL		WEST WALL		CEILING		REMARKS	
		MAT.	FINISH		MAT.	FINISH	MAT.	FINISH	MAT.	FINISH	MAT.	FINISH	TYPE	HEIGHT		
FOOTBALL STADIUM																
A101	ATH. EQ. STORAGE	CONC.	SLR	—	PC/CMU	—	CMU	—	CMU	—	PC	—	ER			
A102	STAIR	CONC.	SLR	—	PC	—	PC	—	PC	—	PC	—	ER			
A102A	RAMP	CONC.	SLR	—	PC	—	PC	—	PC	—	PC	—	ER			
A103	OFFICE	CONC.	SLR	—	CMU	EP-1	CMU	EP-1	CMU	EP-1	CMU	EP-1	ACP1	10'-0"		
A104	VISITING TEAM	CONC.	SLR	—	PC	EP-1	CMU/PC	EP-1	CMU	EP-1	CMU	EP-1	ER/ACP1	VAR./10'-0"		
A104A	SHOWER	CONC.	SLR	—	PC	EP-1	PC	EP-1	CMU	EP-1	PC	EP-1	CP	10'-0"		
A104B	CORRIDOR	CONC.	SLR	—	CMU	EP-1	PC	EP-1	PC	EP-1	CMU	EP-1	ACP1	12'-0" AFF.		
A105	JANITOR	CONC.	SLR	—	CMU	EP-1	CMU	EP-1	PC	EP-1	PC	EP-1	ACP1	10'-0"		
A106	LOBBY	CONC.	SLR	—	PC	EP-1	PC	EP-1	PC	EP-1	PC	EP-1	ER			
A107	REFEREES	CONC.	SLR	—	PC	EP-1	CMU	EP-1	PC	EP-1	CMU	EP-1	ACP1	8'-0"		
A107A	REF. TOILET	CONC.	SLR	—	PC	EP-1	CMU	EP-1	CMU	EP-1	CMU	EP-1	ACP2/CP	8'-0"		
A108	FIRST AID	CONC.	SLR	—	PC	EP-1	CMU	EP-1	CMU	EP-1	CMU	EP-1	ACP1	8'-0"		
A108A	TOILET	CONC.	SLR	—	PC	EP-1	CMU	EP-1	CMU	EP-1	CMU	EP-1	ACP1	8'-0"		
A109	MEN'S TOILET	CONC.	SLR	—	CMU	EP-1	CMU/PC	EP-1	PC/CMU	EP-1	CMU/PC	EP-1	ACP1	10'-0"		
A110	WOMEN'S TOILET	CONC.	SLR	—	CMU	EP-1	CMU/PC	EP-1	PC/CMU	EP-1	PC/CMU	EP-1	ACP1	10'-0"	*** PAINT ELEVATOR DOORS AND FRAMES, BOTH SIDES, 1P-2	
A111	STORAGE	CONC.	SLR	—	CMU	EP-1	PC	EP-1	PC/CMU	EP-1	PC	EP-1	ER			
A112	CONCESSION	CONC.	SLR	—	PC/CMU	EP-1	PC	EP-1	CMU/PC	EP-1	PC	EP-1	ACP2	10'-0"		
A113	ELEVATOR	CONC.	SLR	—	PC	EP-1	CMU	EP-1	PC	EP-1	PC	EP-1	ACP1	10'-0"		
A114	ELEVATOR EQ.	CONC.	SLR	—	PC	EP-1	PC	EP-1	PC	EP-1	PC	EP-1	ER			
A115	JANITOR	CONC.	SLR	—	CMU	EP-1	CMU	EP-1	PC	EP-1	PC	EP-1	ACP1	10'-0"		
A116	LOBBY	CONC.	SLR	—	PC	EP-1	PC	EP-1	PC	EP-1	PC	EP-1	ER			
A117	HOME TEAM	CONC.	SLR	—	PC	EP-1	CMU/PC	EP-1	PC/CMU	EP-1	CMU	EP-1	ER/ACP1	VAR/10'-0"		
A117A	SHOWER	CONC.	SLR	—	PC	EP-1	PC	EP-1	PC	EP-1	CMU	EP-1	CP	10'-0"		
A117B	CORRIDOR	CONC.	SLR	—	CMU	EP-1	PC	EP-1	CMU	EP-1	PC	EP-1	ACP1	12'-0" AFF.		
A118	OFFICE	CONC.	SLR	—	CMU	EP-1	CMU	EP-1	CMU	EP-1	CMU	EP-1	ACP1	10'-0"		
A118A	COACH TOILET	CONC.	SLR	—	CMU	EP-1	CMU	EP-1	CMU	EP-1	CMU	EP-1	ACP2/CP	8'-0"		
A119	LAWN EQ. STORAGE	CONC.	SLR	—	PC/CMU	—	CMU	—	CMU	—	CMU/PC	—	ER			
A120	MECHANICAL	CONC.	SLR	—	CONC.	—	CMU	—	CMU	—	CMU/PC	—	ER			
A121	ELECTRICAL	CONC.	SLR	—	PC	—	CMU	—	PC/CMU	—	PC	—	ER			
A122	STAIR	CONC.	SLR	—	PC	—	PC	—	PC	—	PC	—	ER			
A122A	RAMP	CONC.	SLR	—	PC	—	PC	—	PC	—	PC	—	ER			
B112	MEZZANINE	CONC.	SLR	—	PC/CMU	—	PC/CMU	—	PC	—	CMU/PC	—	ER			
FOOTBALL STADIUM PRESSBOX																
A123	PRESSBOX	CONC.	SLR	—	PC/CMU	EP-1	PC/CMU	EP-1	PC/CMU	EP-1	PC/CMU	EP-1	GYP	B.O.S.	*** PAINT ELEVATOR DOORS AND FRAMES, BOTH SIDES, 1P-2	
A124	RADIO	CONC.	SLR	—	PC	EP-1	CMU	EP-1	CMU	EP-1	CMU	EP-1	ACP1	8'-0"		
A125	TELEVISION	CONC.	SLR	—	PC	EP-1	CMU	EP-1	CMU	EP-1	PC	EP-1	ACP1	8'-0"		
A126	RADIO	CONC.	SLR	—	PC	EP-1	CMU	EP-1	PC	EP-1	CMU	EP-1	ACP1	8'-0"		
A127	TELEVISION	CONC.	SLR	—	PC	EP-1	CMU	EP-1	CMU	EP-1	CMU	EP-1	ACP1	8'-0"		
VISITOR TOILET & CONCESSION FLOOR PLAN																
B101	CONCESSION	CONC.	SLR	—	CMU	EP-1	CMU	EP-1	CMU	EP-1	CMU	EP-1	ACP2	10'-0"		
B101A	WOMEN'S TOILET	CONC.	SLR	—	CMU	EP-1	CMU	EP-1	CMU	EP-1	CMU	EP-1	ACP1	10'-0"		
B103	JAN./MECHANICAL	CONC.	SLR	—	CMU	EP-1	CMU	EP-1	CMU	EP-1	CMU	EP-1	ES	—		
B104	LAWN STORAGE	CONC.	SLR	—	CMU	EP-1	CMU	EP-1	CMU	EP-1	CMU	EP-1	ES	—		
B105	MEN'S TOILET	CONC.	SLR	—	CMU	EP-1	CMU	EP-1	CMU	EP-1	CMU	EP-1	ACP1	10'-0"		
TICKET BOOTH																
C101	TICKETS	CONC.	SLR	—	CMU	EP-1	CMU	EP-1	CMU	EP-1	CMU	EP-1	ES	—		
C102	TICKETS	CONC.	SLR	—	CMU	EP-1	CMU	EP-1	CMU	EP-1	CMU	EP-1	ES	—		

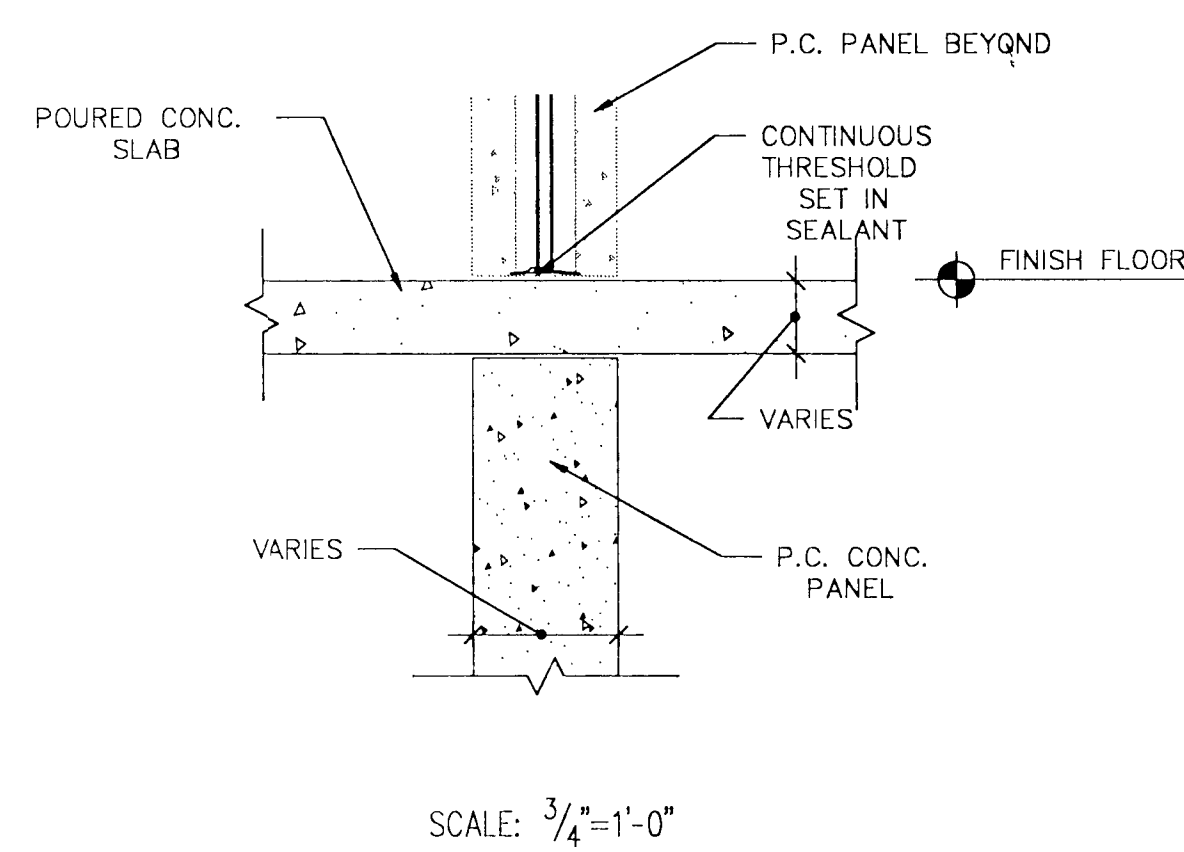


SCALE: 3/4"=1'-0"
S2

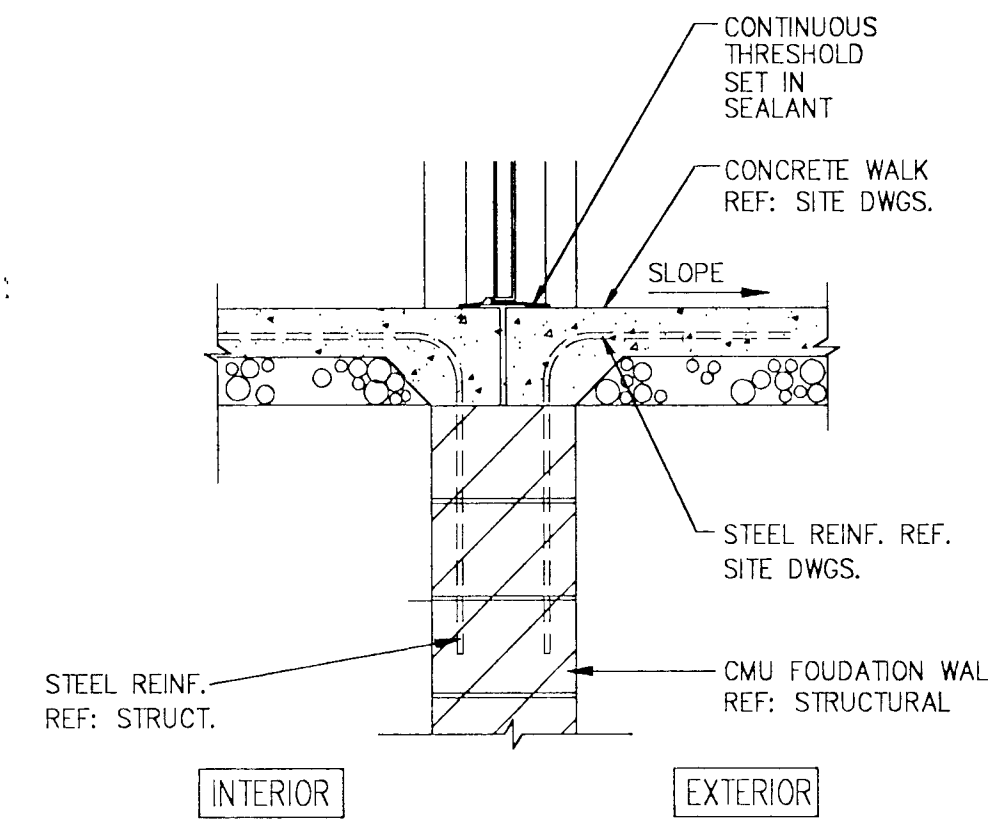


SCALE: 3/4"=1'-0"
S1

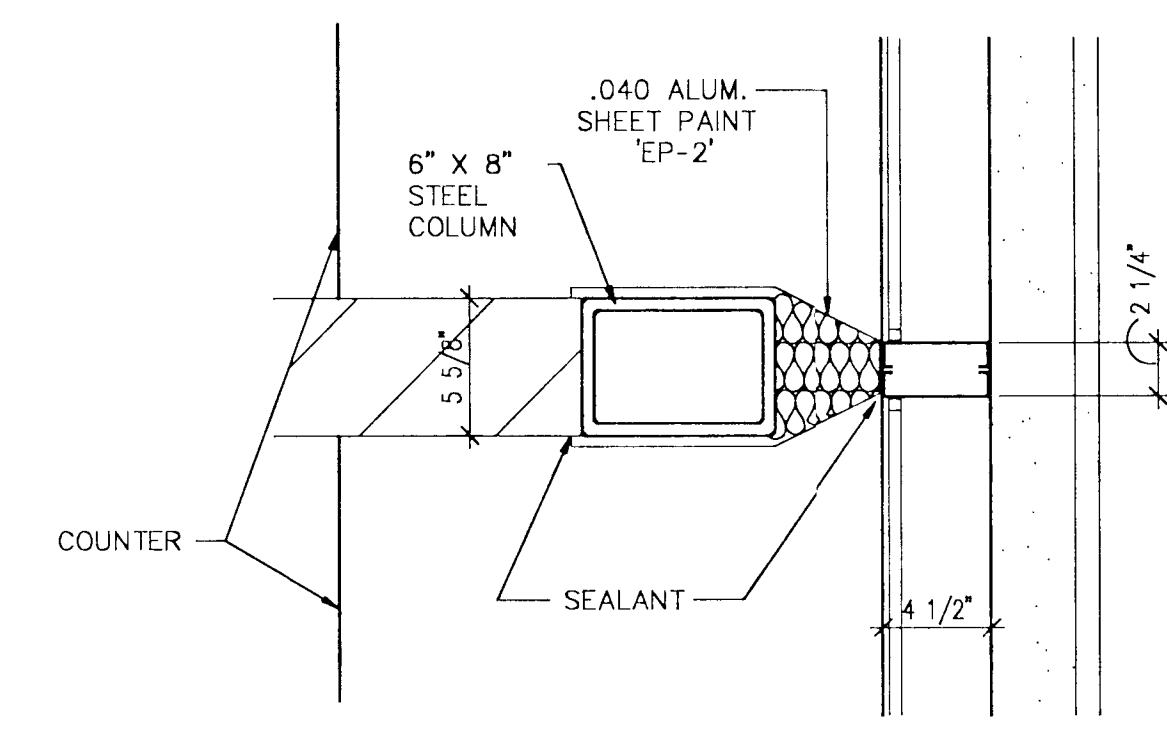


SLIDING DOOR JAMB DETAIL
SCALE: 1 1/2"=1'-0"
A504

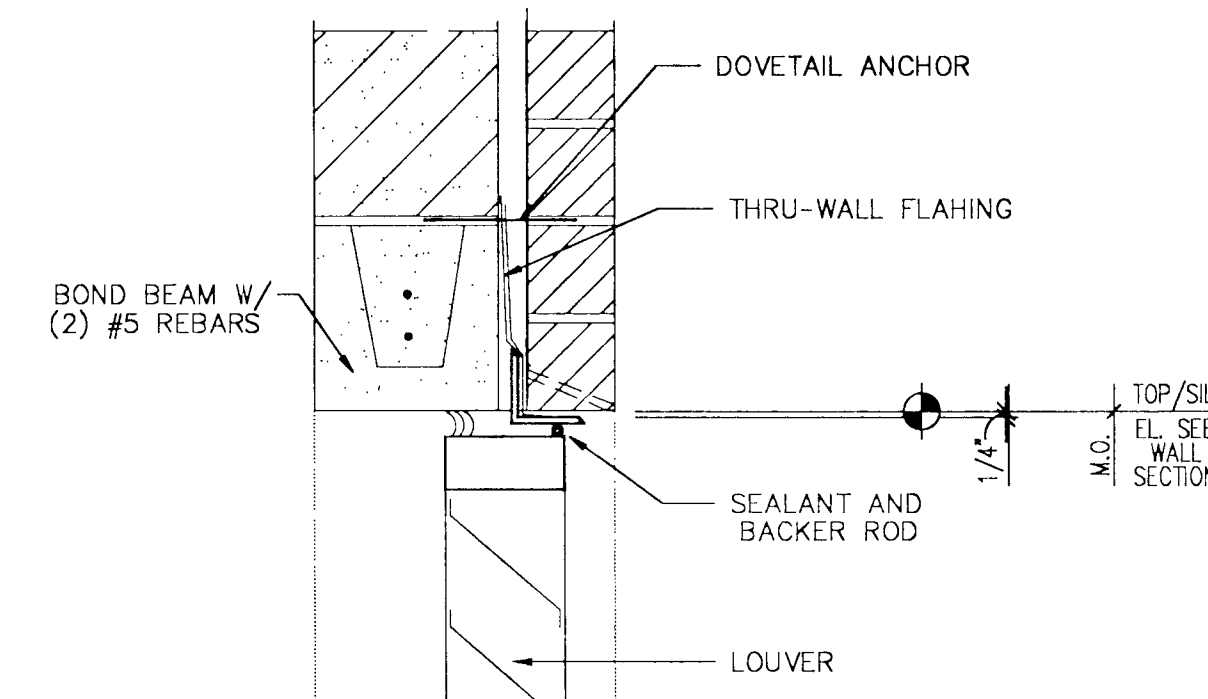


LOUVER HEAD
SCALE: 1 1/2"=1'-0"
A502

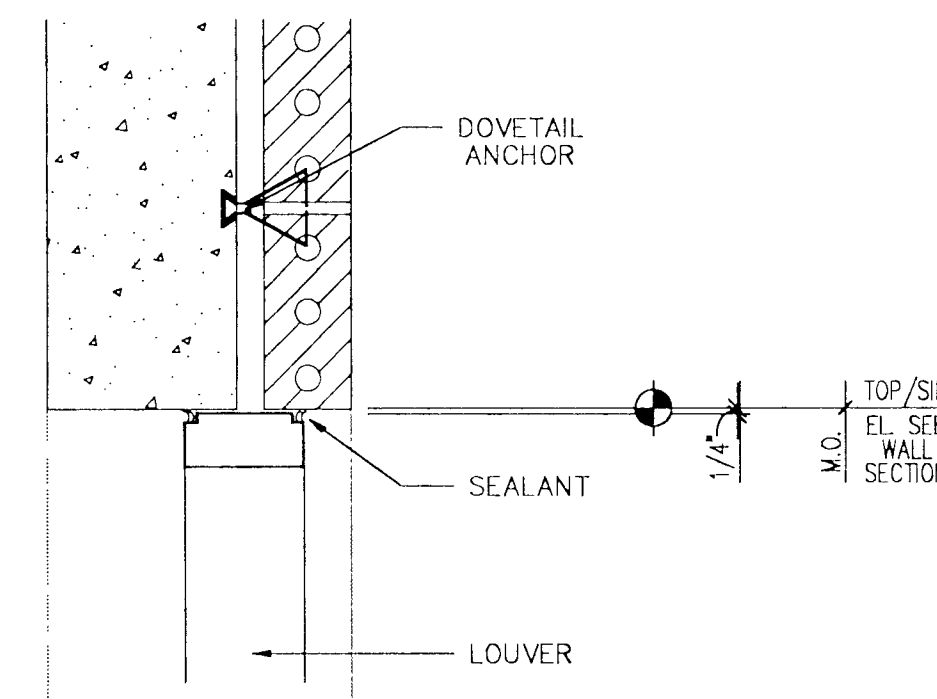


LOUVER JAMB
SCALE: 1 1/2"=1'-0"
A502

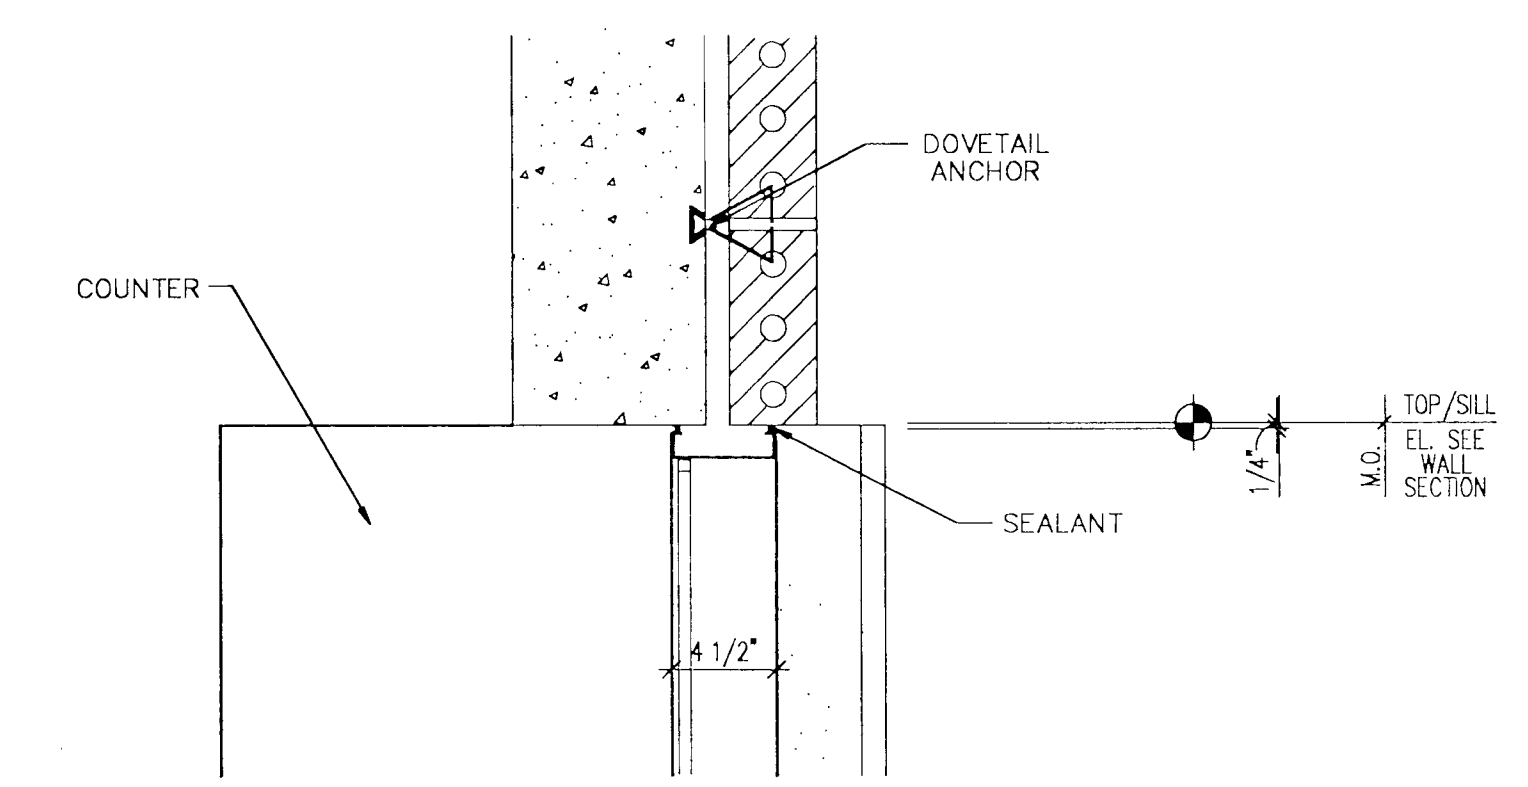


SLIDING DOOR JAMB DETAIL
SCALE: 1 1/2"=1'-0"
A504

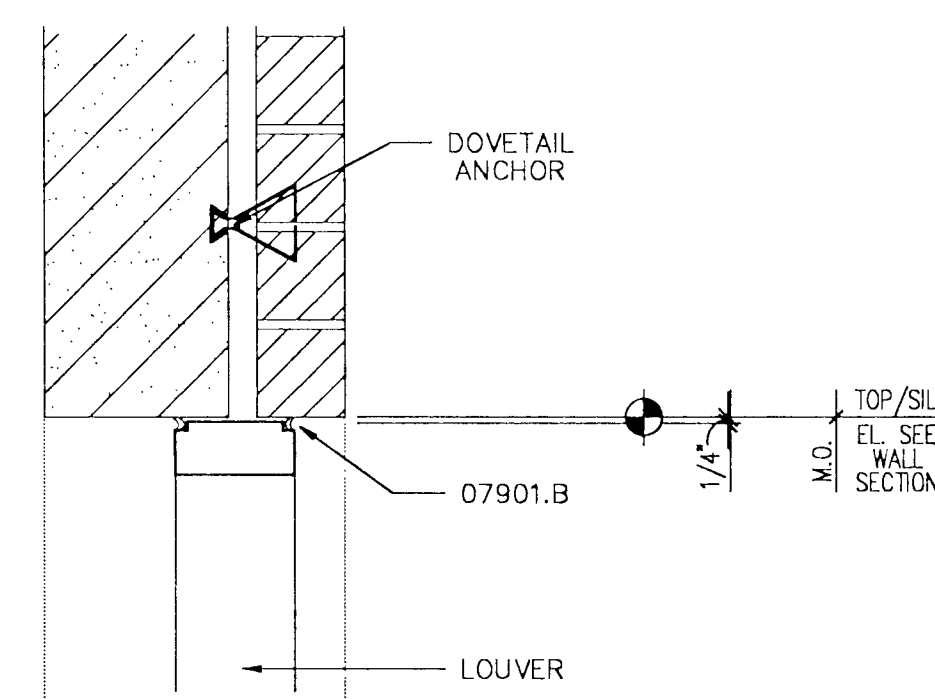


LOUVER JAMB
SCALE: 1 1/2"=1'-0"
A502

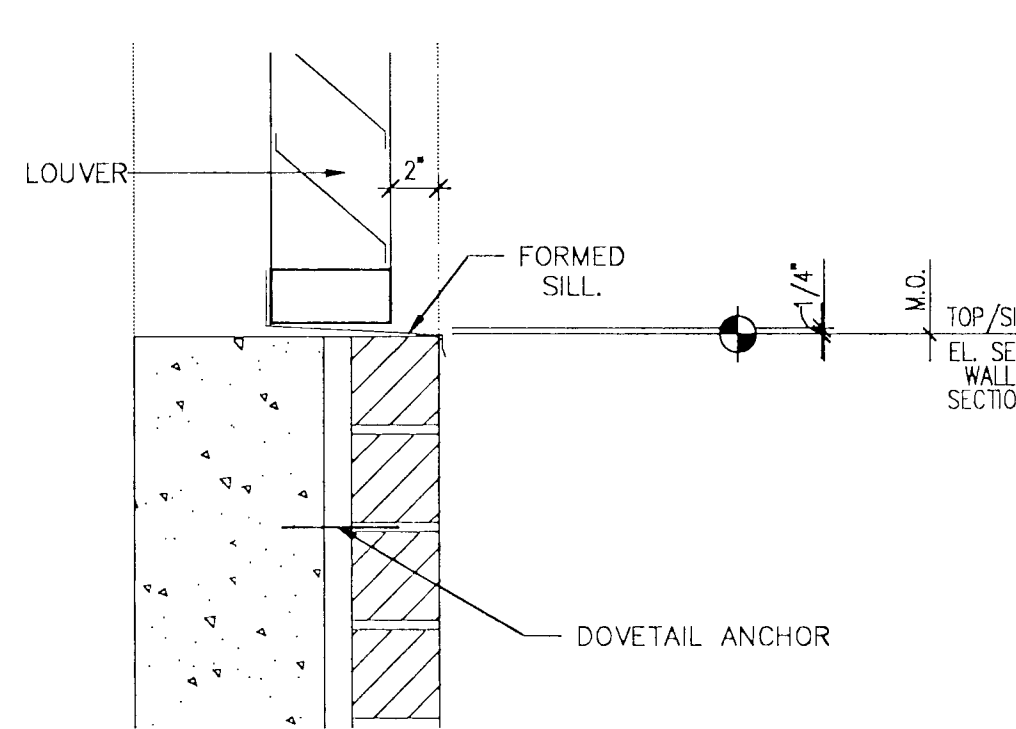


LOUVER SILL
SCALE: 1 1/2"=1'-0"
A502

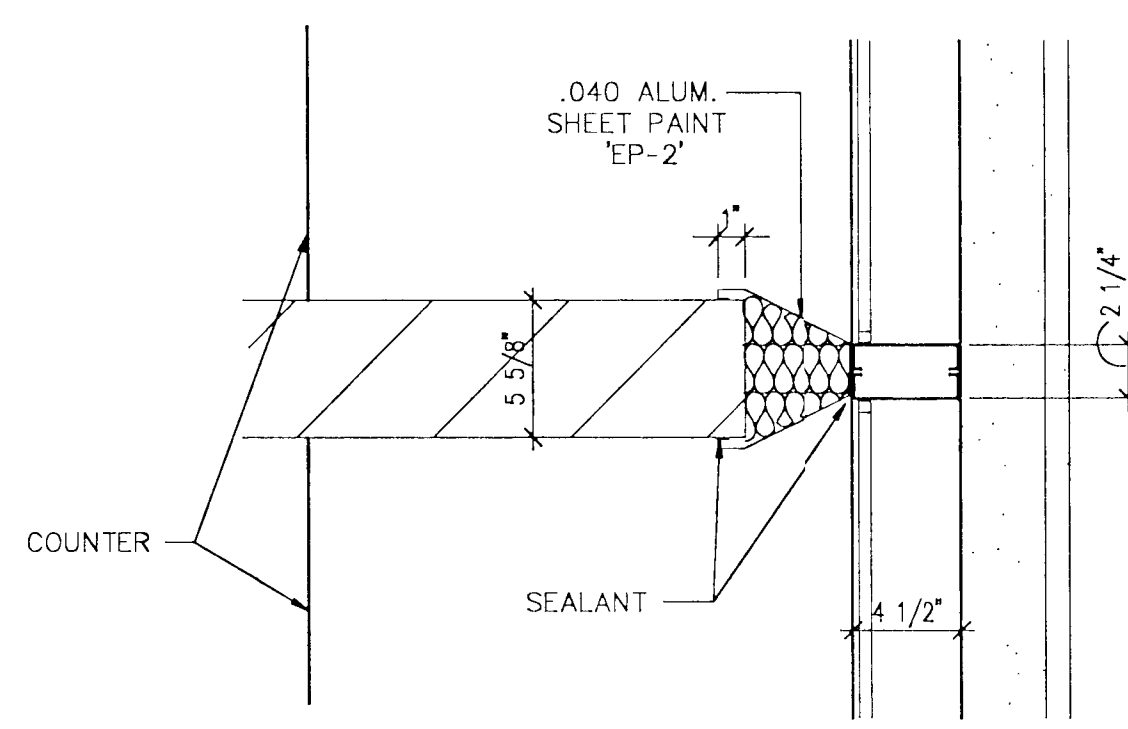


SLIDING DOOR JAMB DETAIL
SCALE: 1 1/2"=1'-0"
A504

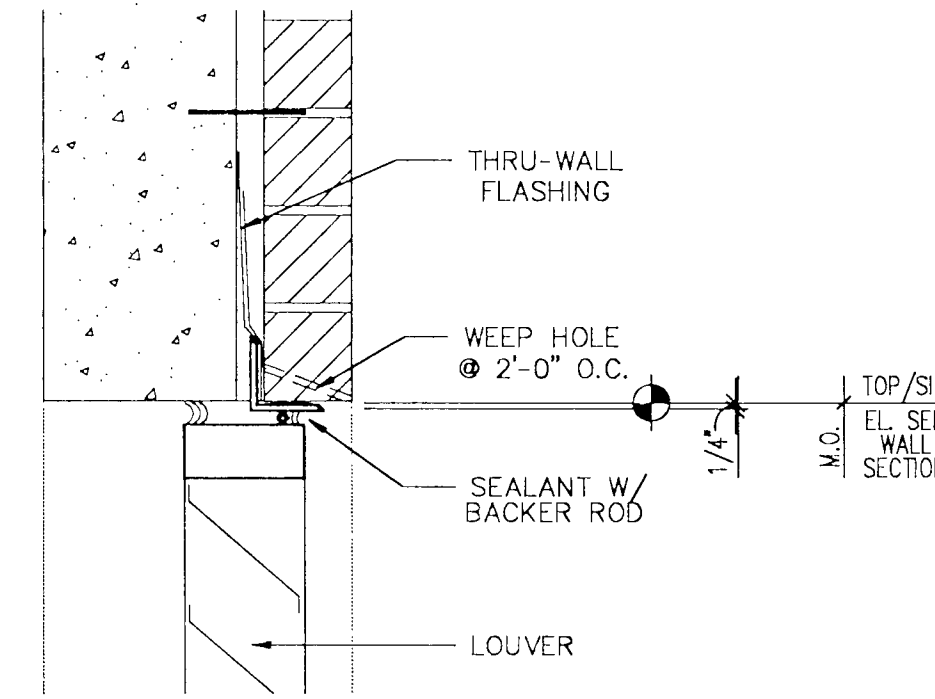


LOUVER HEAD
SCALE: 1 1/2"=1'-0"
A502

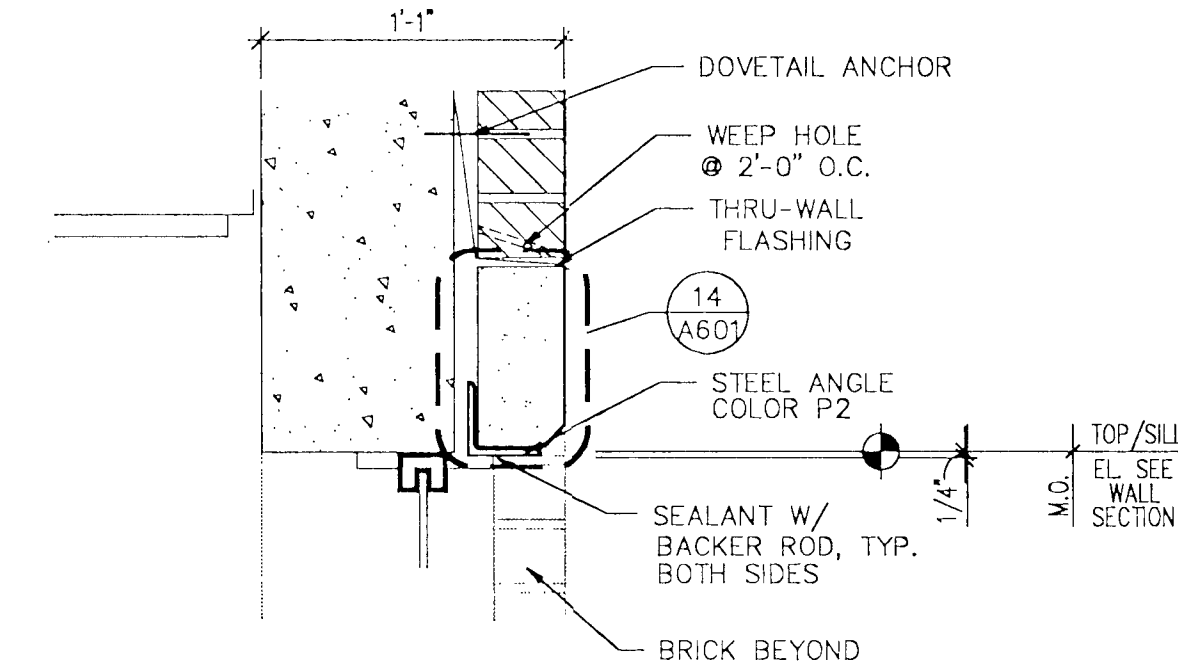

SLIDING DOOR HEAD DETAIL
SCALE: 1 1/2"=1'-0"
A502

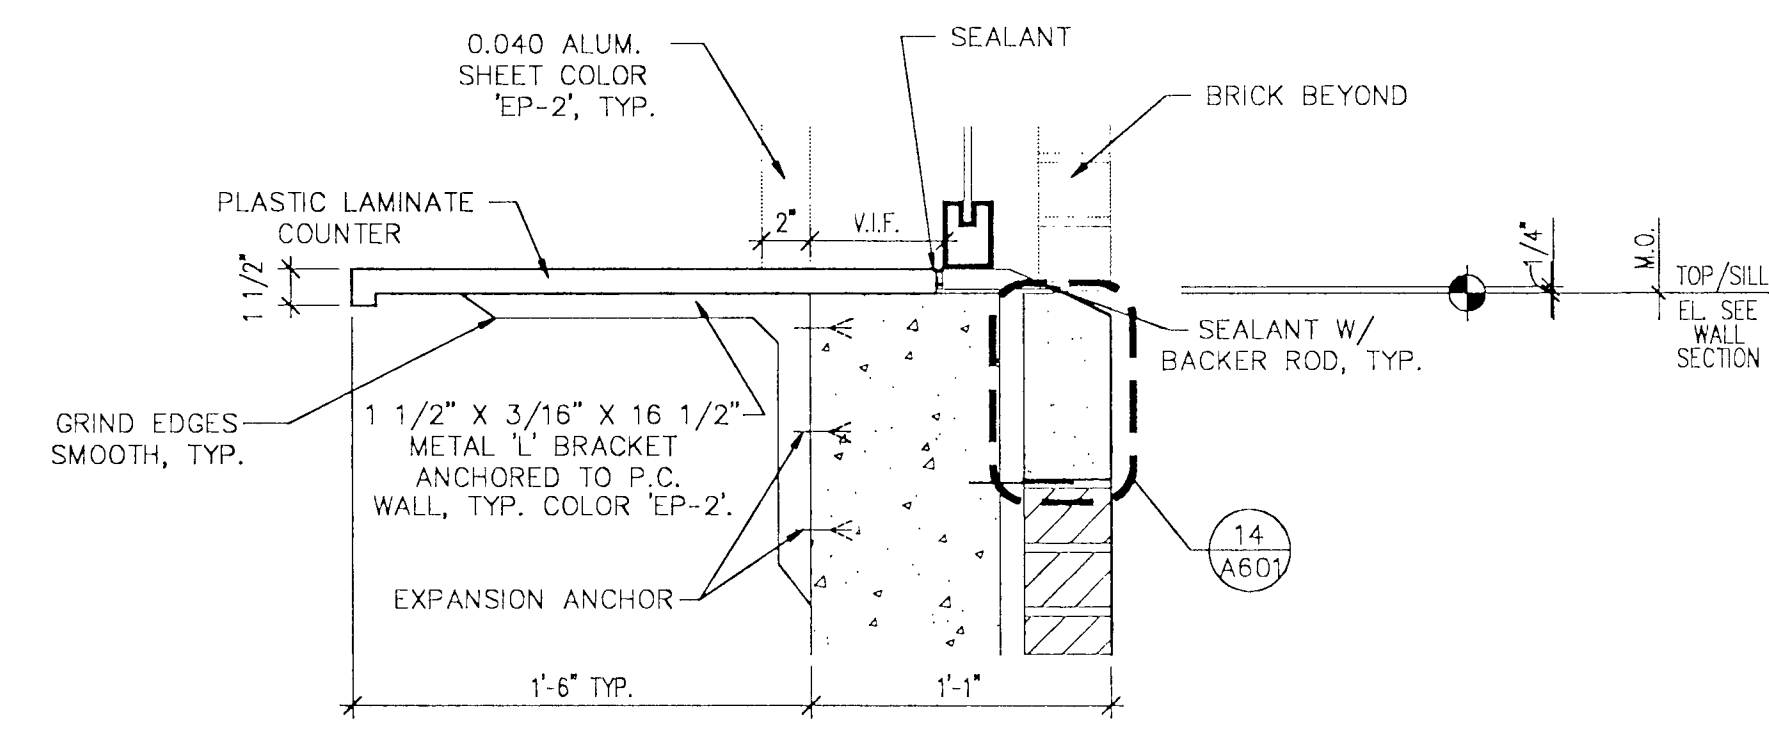

TYPICAL SILL & COUNTER DETAIL
SCALE: 1 1/2"=1'-0"
A504

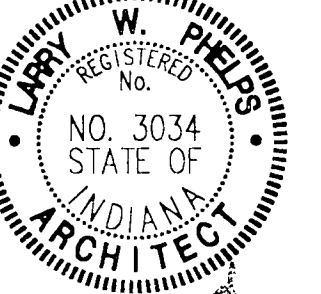

THE ODLE MCGUIRE & SHOOK CORPORATION
ARCHITECTURE • ENGINEERING • LANDSCAPE ARCHITECTURE • INTERIOR DESIGN
8765 NORTH STATE ROAD 37, POST OFFICE BOX 2148, BLOOMINGTON, INDIANA 47402, 812/876-2020
8275 ALLISON POINTE TRAIL, POST OFFICE BOX 50428, INDIANAPOLIS, INDIANA 46250, 317/842-0080


REVISIONS

© Copyright 1994 by THE ODLE MCGUIRE & SHOOK CORPORATION. Copyright includes architecture work, building design, plans or drawings, and specifications. Architectural work is the overall form as well as the arrangement and composition of space and materials in the design. Reproduction without written permission is prohibited.

MICHIGAN CITY SPORTS COMPLEX
AMES FIELD
MICHIGAN CITY, INDIANA

PROJECT NO. 93052
DATE MAY 31, 1994
drawn by: MFM
checked by: GKJ


A502
DOOR DETAILS/
LOUVER DETAILS

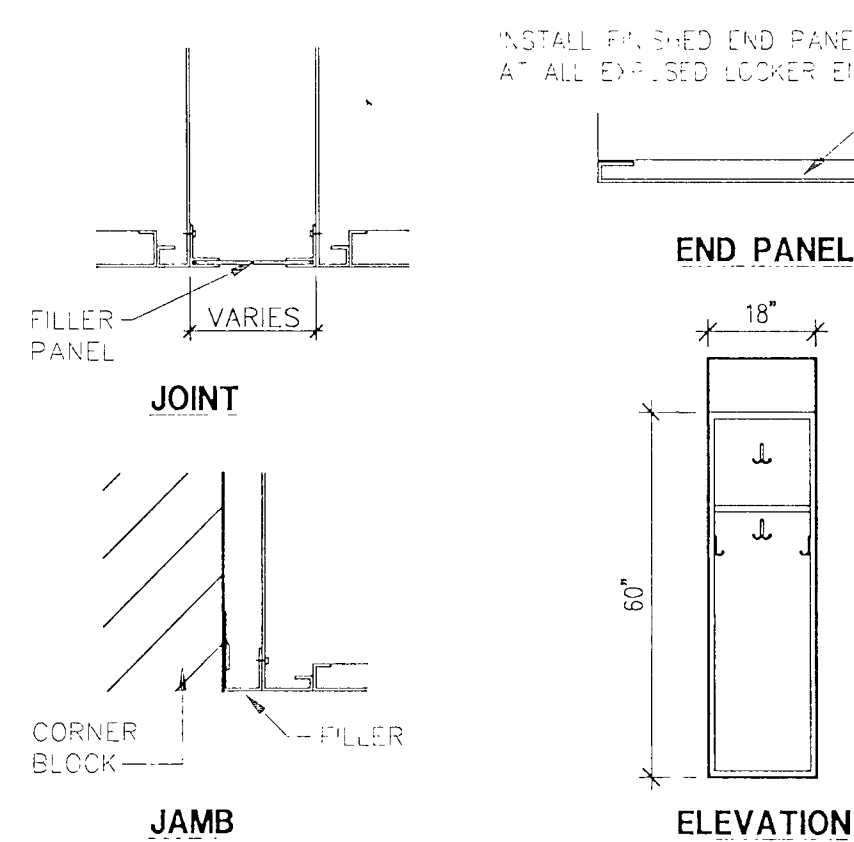

LOCKER DETAILS

SCALE: NONE


13.A
A601

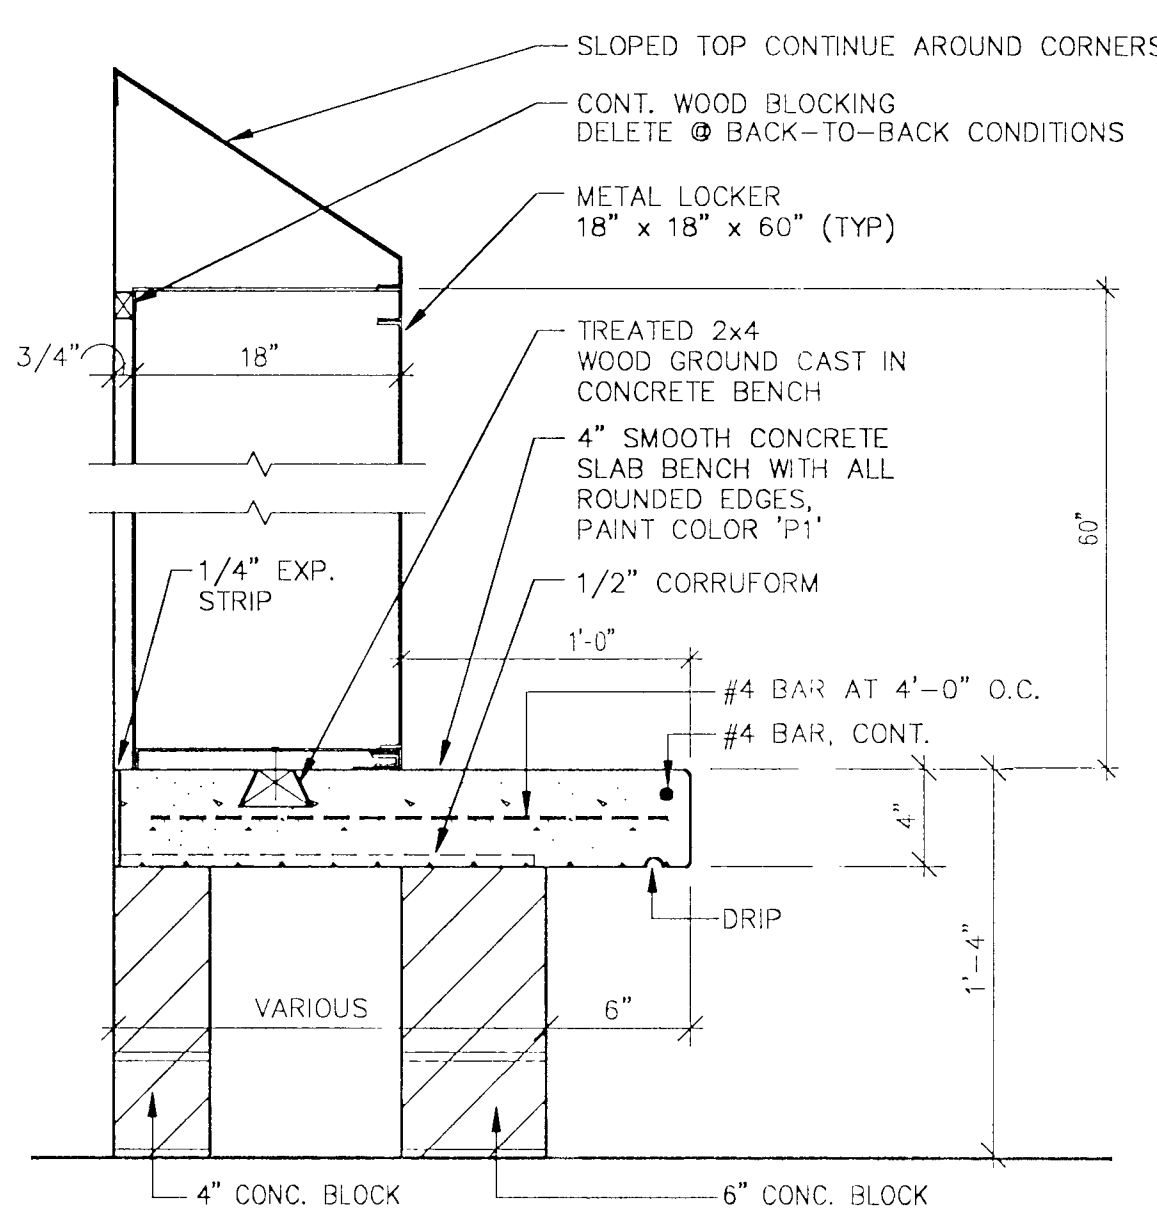

LOCKER BENCH SECTION

SCALE: 1 1/2" = 1'-0"


13
A601

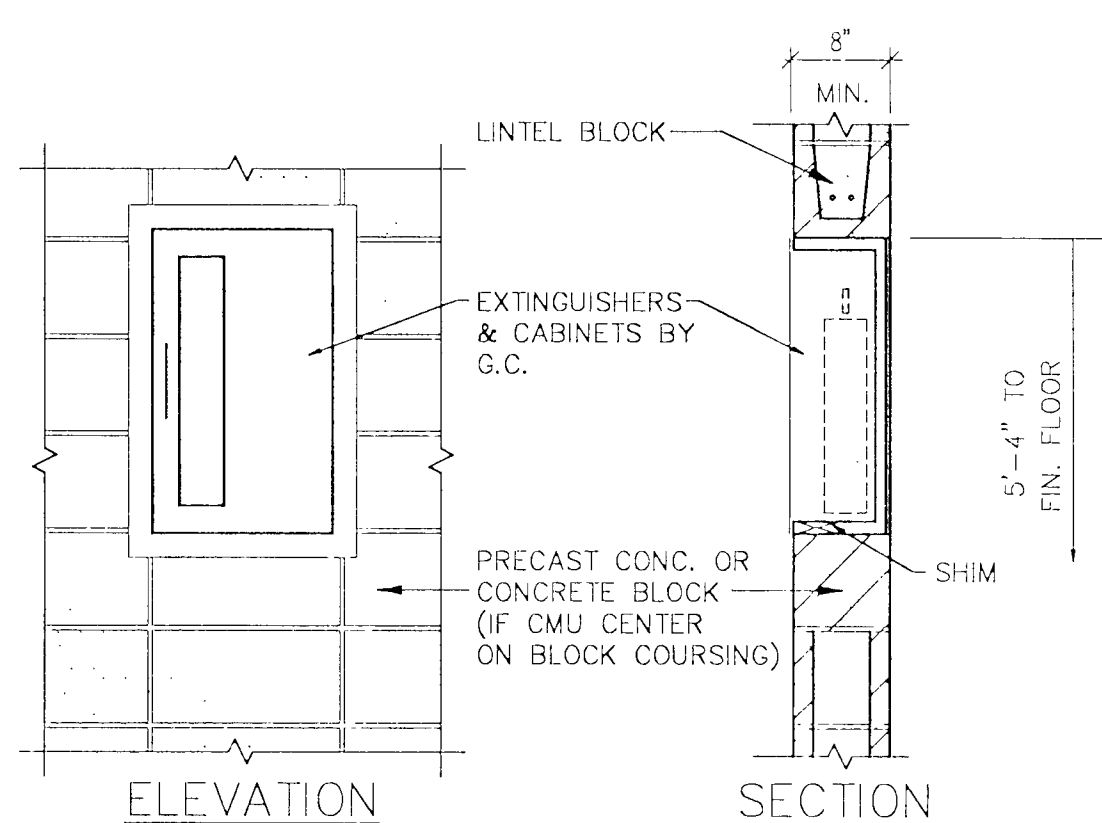

FIRE EXTINGUISHER CABINET

SCALE: 3/4" = 1'-0"

12
A601

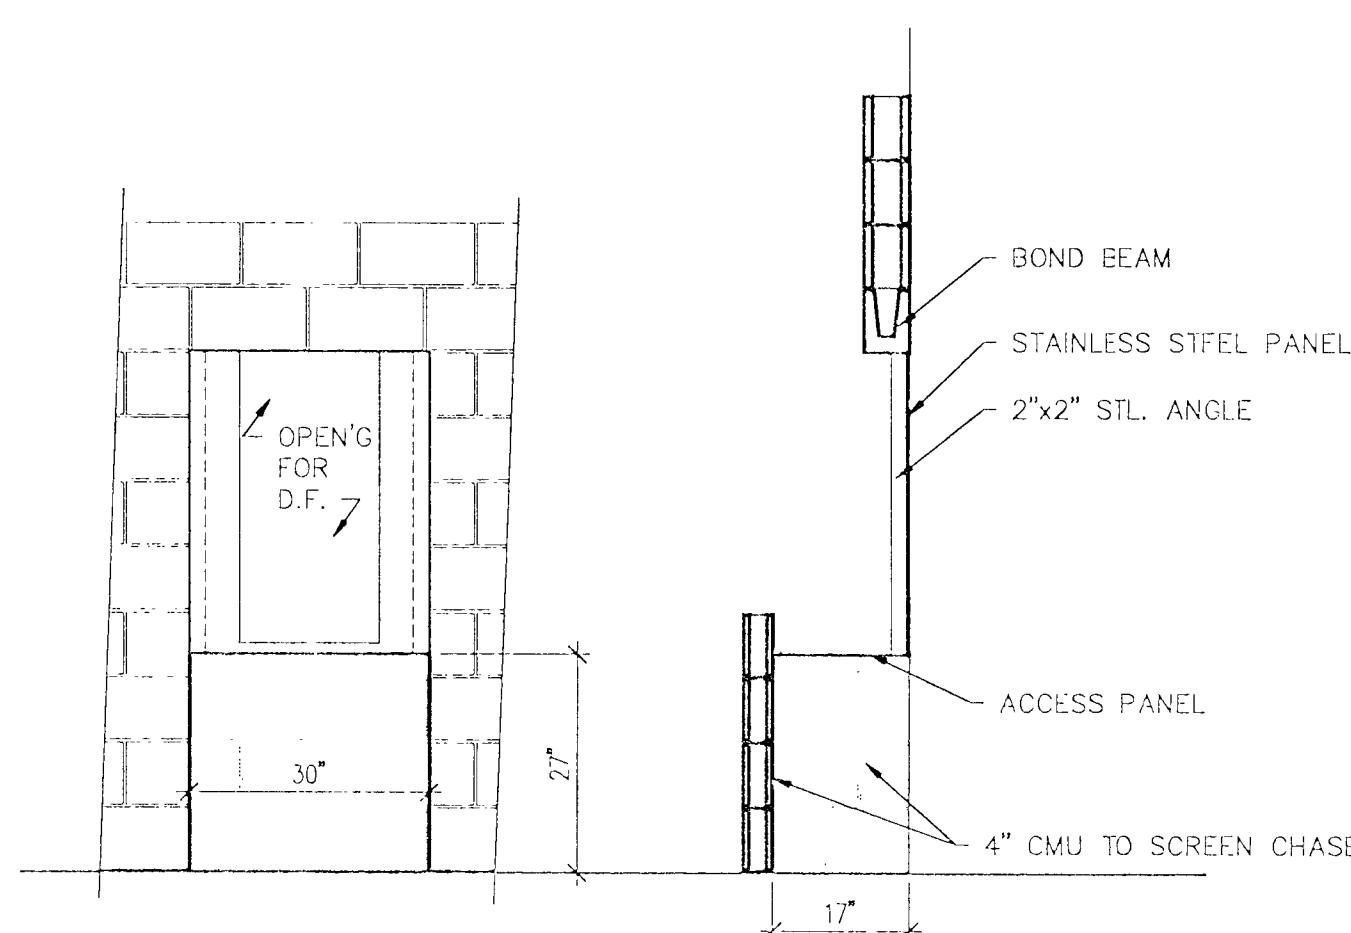

PLAN DETAIL


SCALE: 1/2" = 1'-0"

11
A601

SPECIAL STONE SHAPE

SCALE: 3" = 1'-0"


14
A601

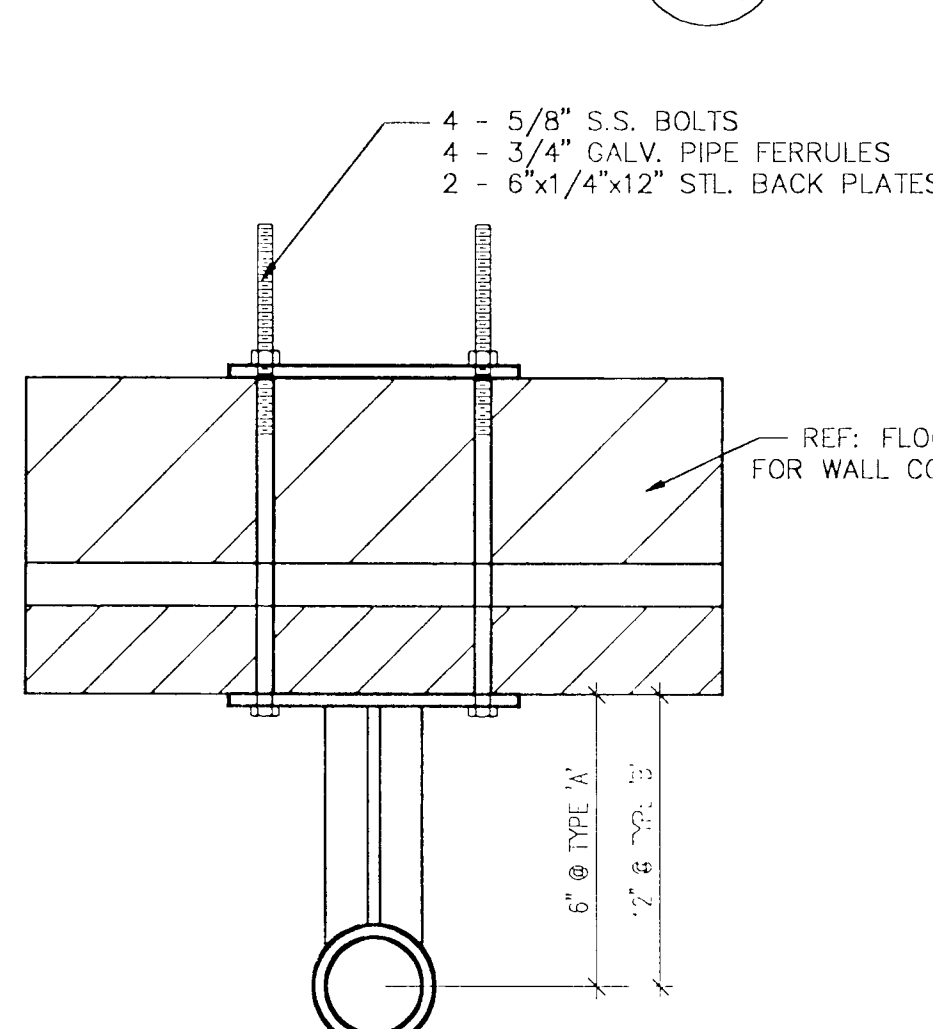

FLAGPOLE DETAILS

SCALE: 1 1/2" = 1'-0"


10
A601

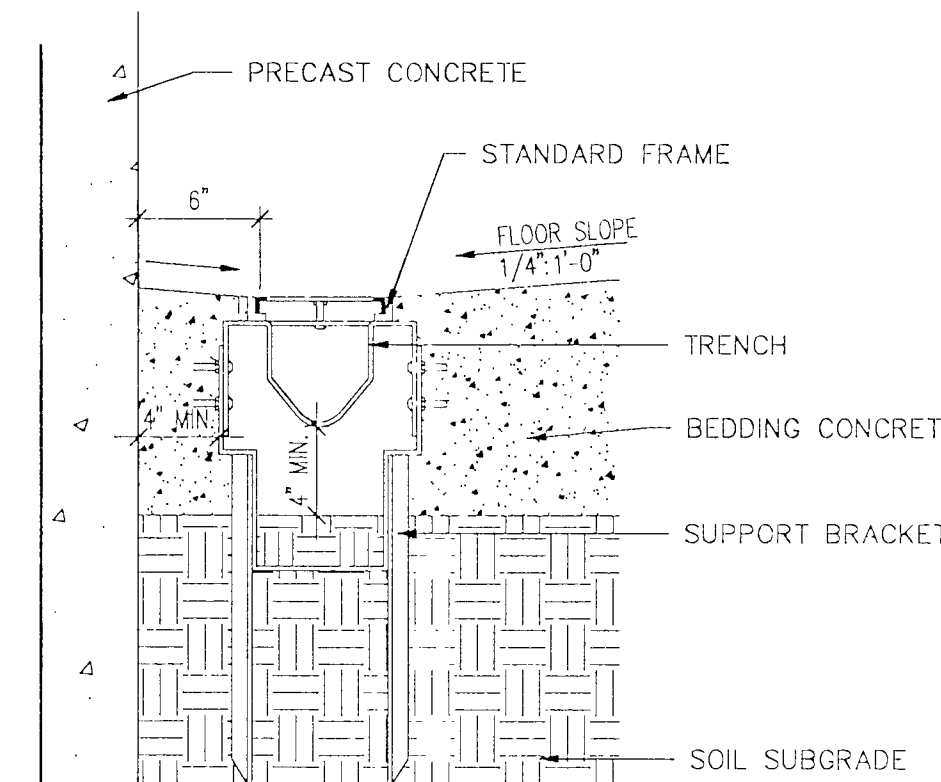

TYPICAL SHOWER DRAIN

SCALE: 1 1/2" = 1'-0"

9
A601

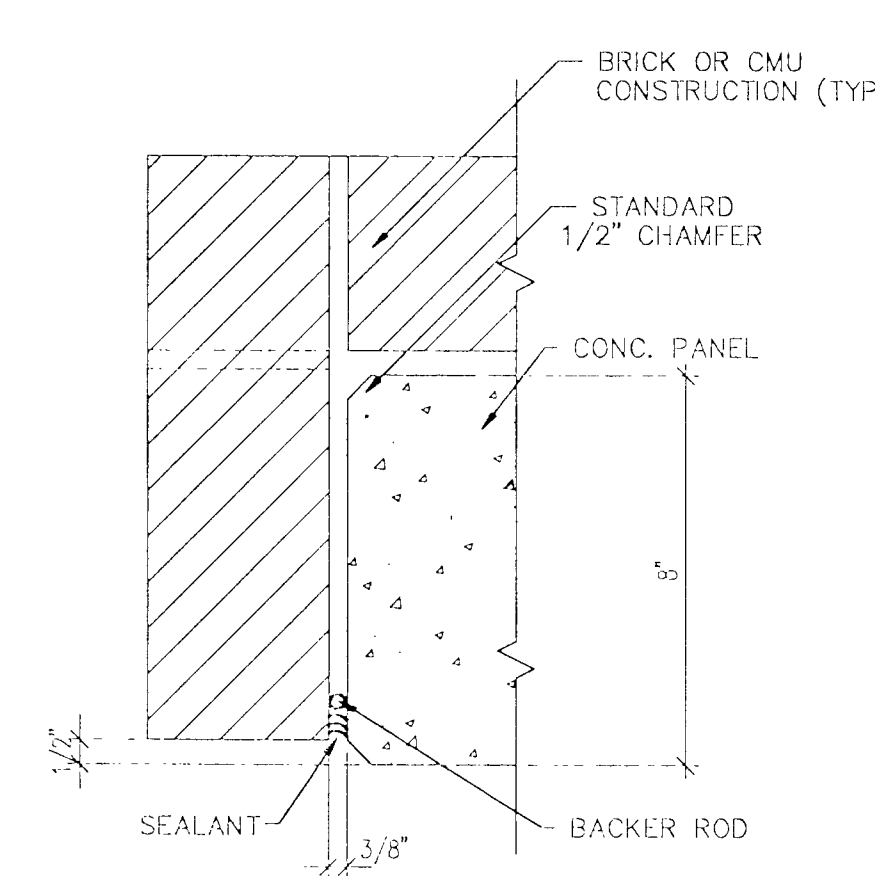

PLAN DETAIL


SCALE: 3" = 1'-0" NOTE: TYP. @ P.C. COLUMN OR PANEL

8
A601

CONCESSION STAND ROLLING SHUTTER/COUNTER DETAIL

SCALE: 1" = 1'-0"


15
A601

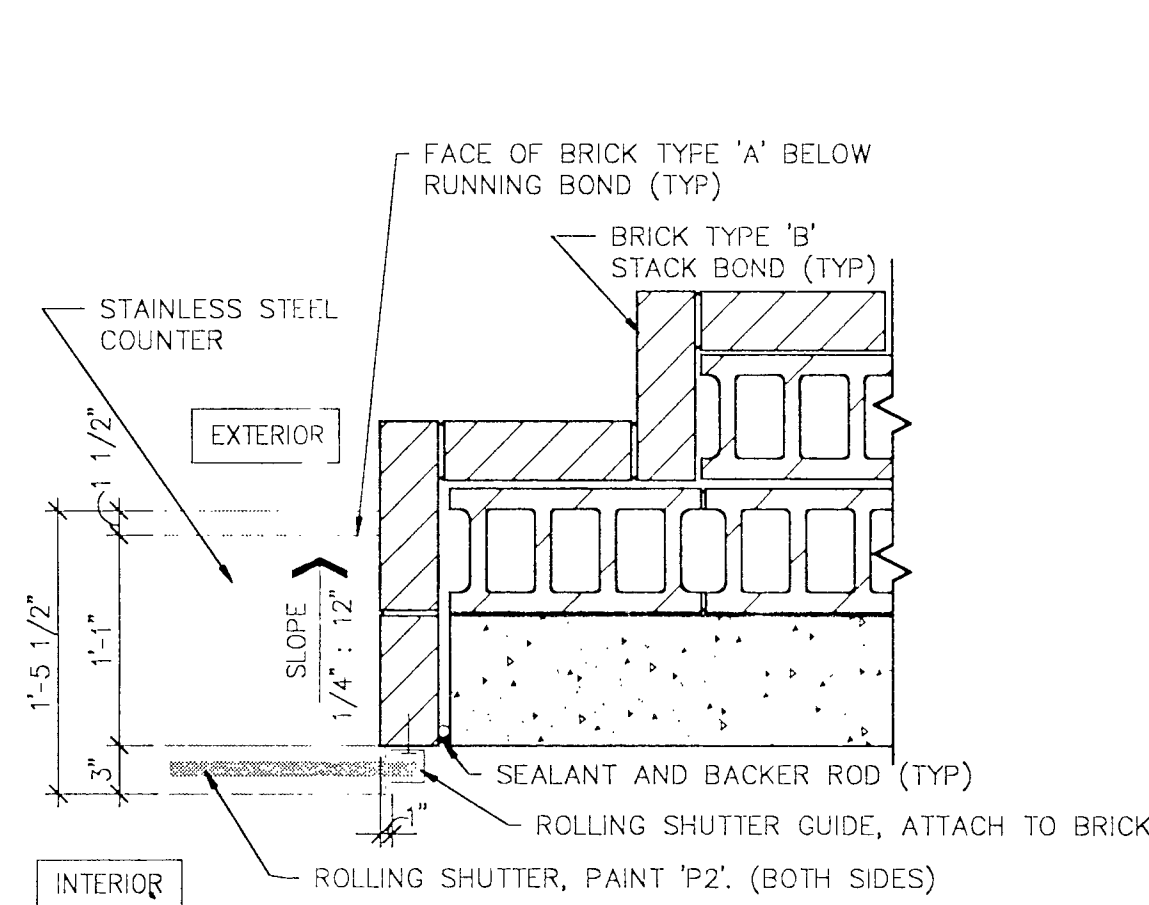

TYPICAL PILASTER DETAIL

SCALE: 1" = 1'-0"


7A
A601

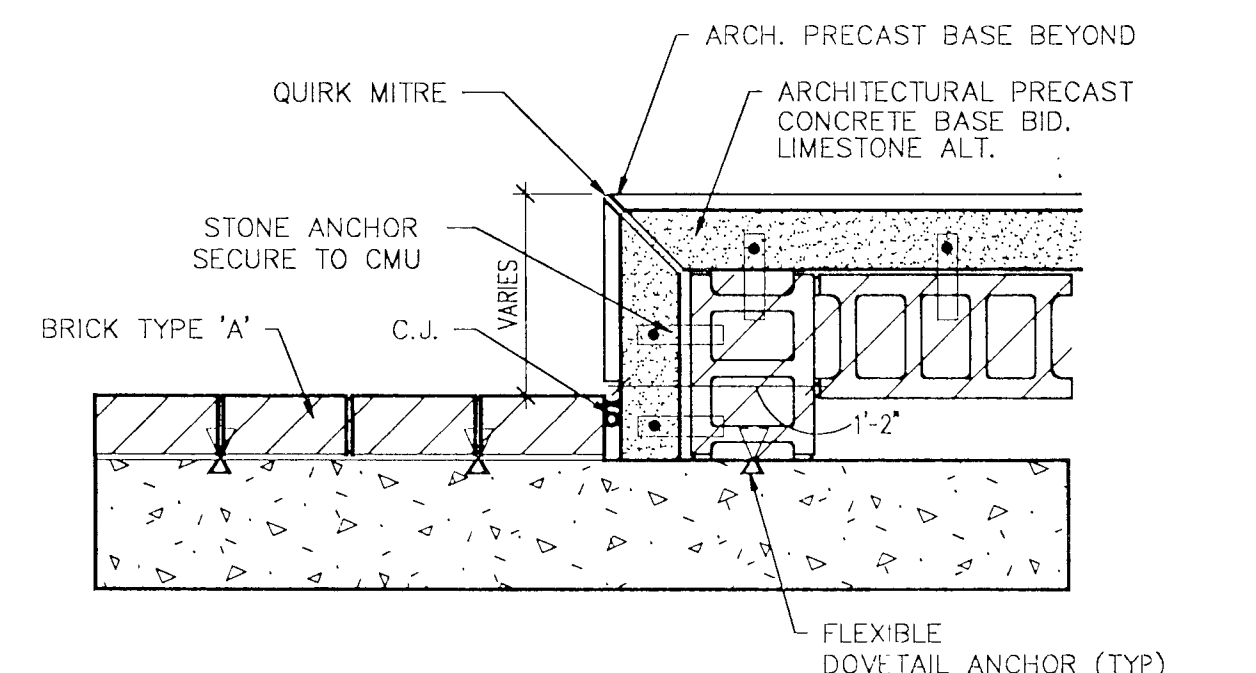

TYPICAL PILASTER DETAIL

SCALE: 1" = 1'-0"


7
A601

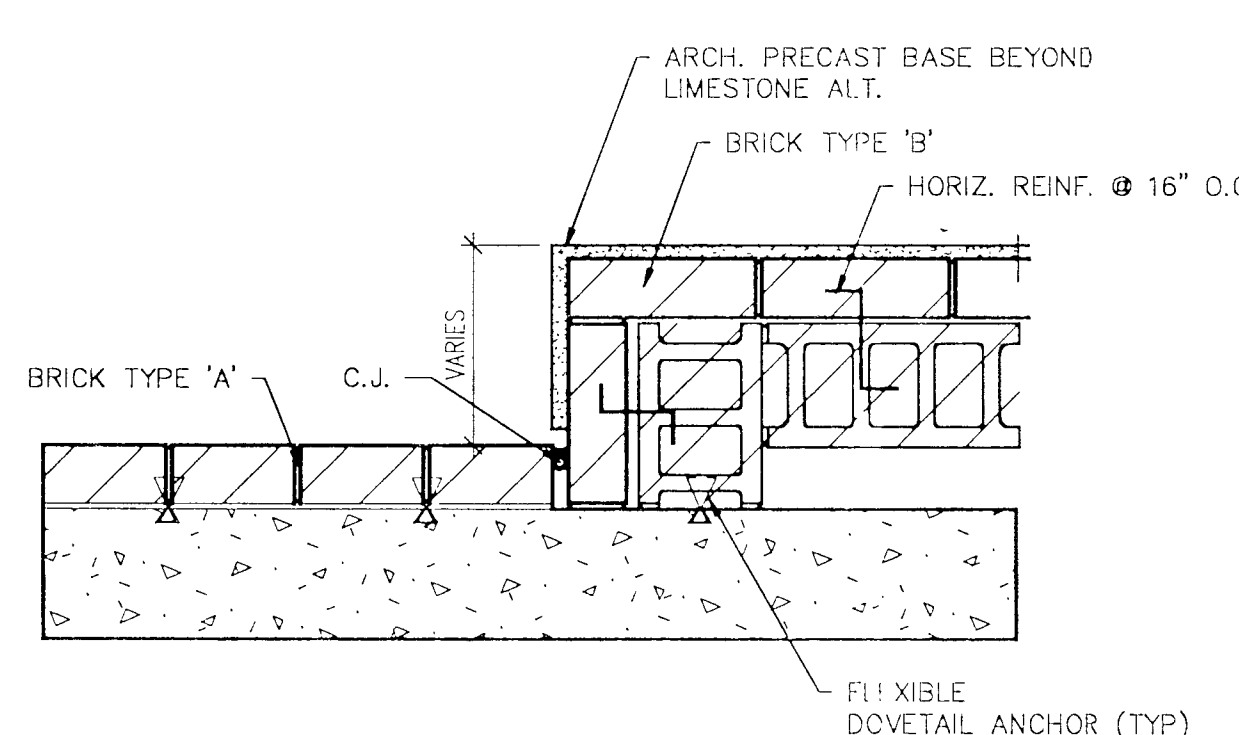

TYPICAL PILASTER DETAIL

SCALE: 1" = 1'-0"


6
A601

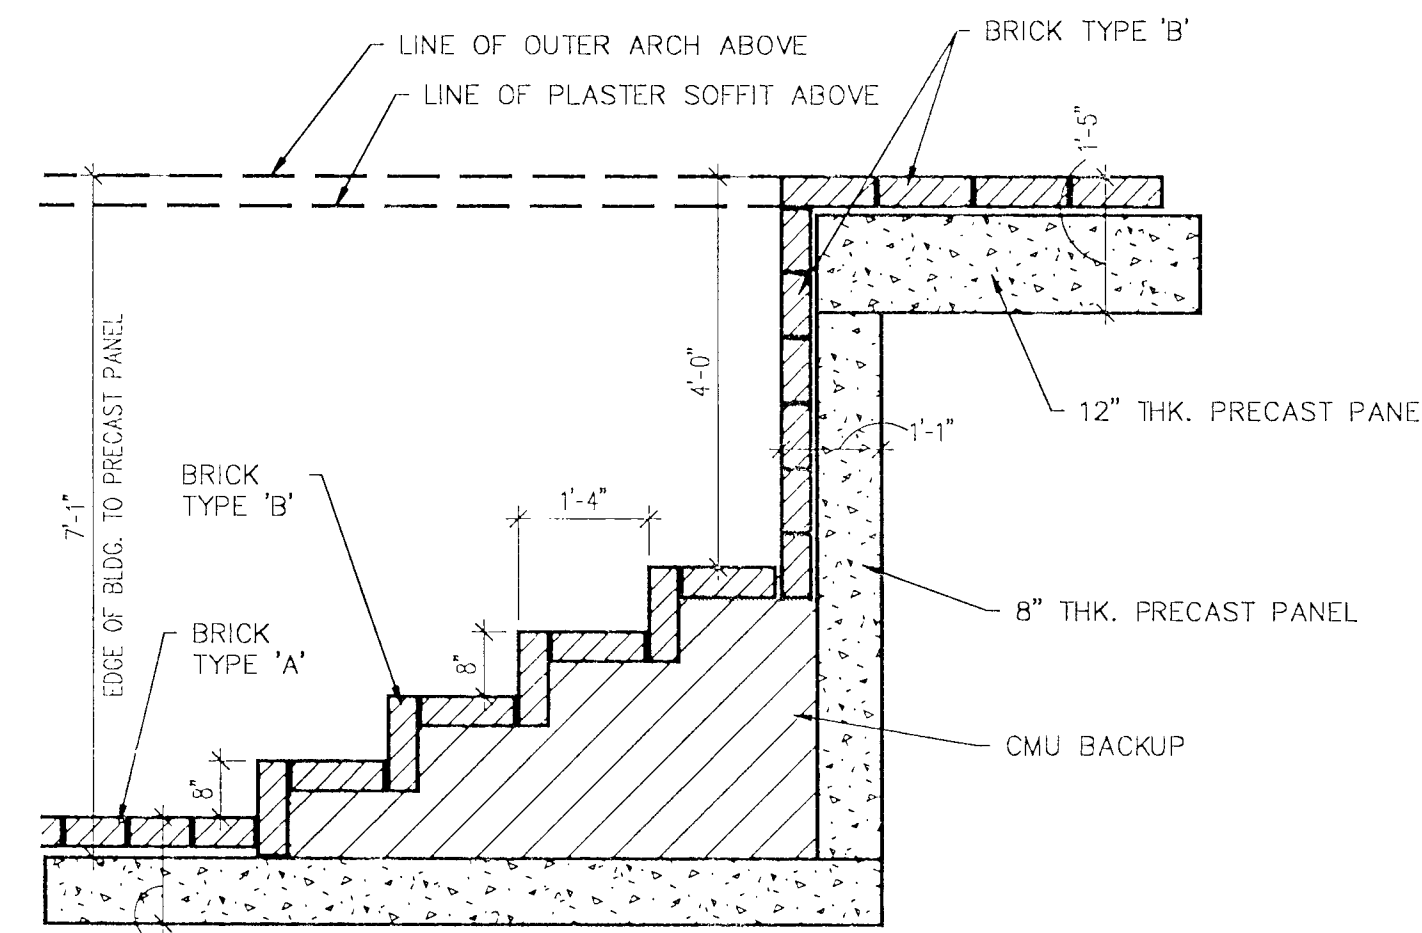

PLAN DETAIL

SCALE: 1/2" = 1'-0"


5
A601

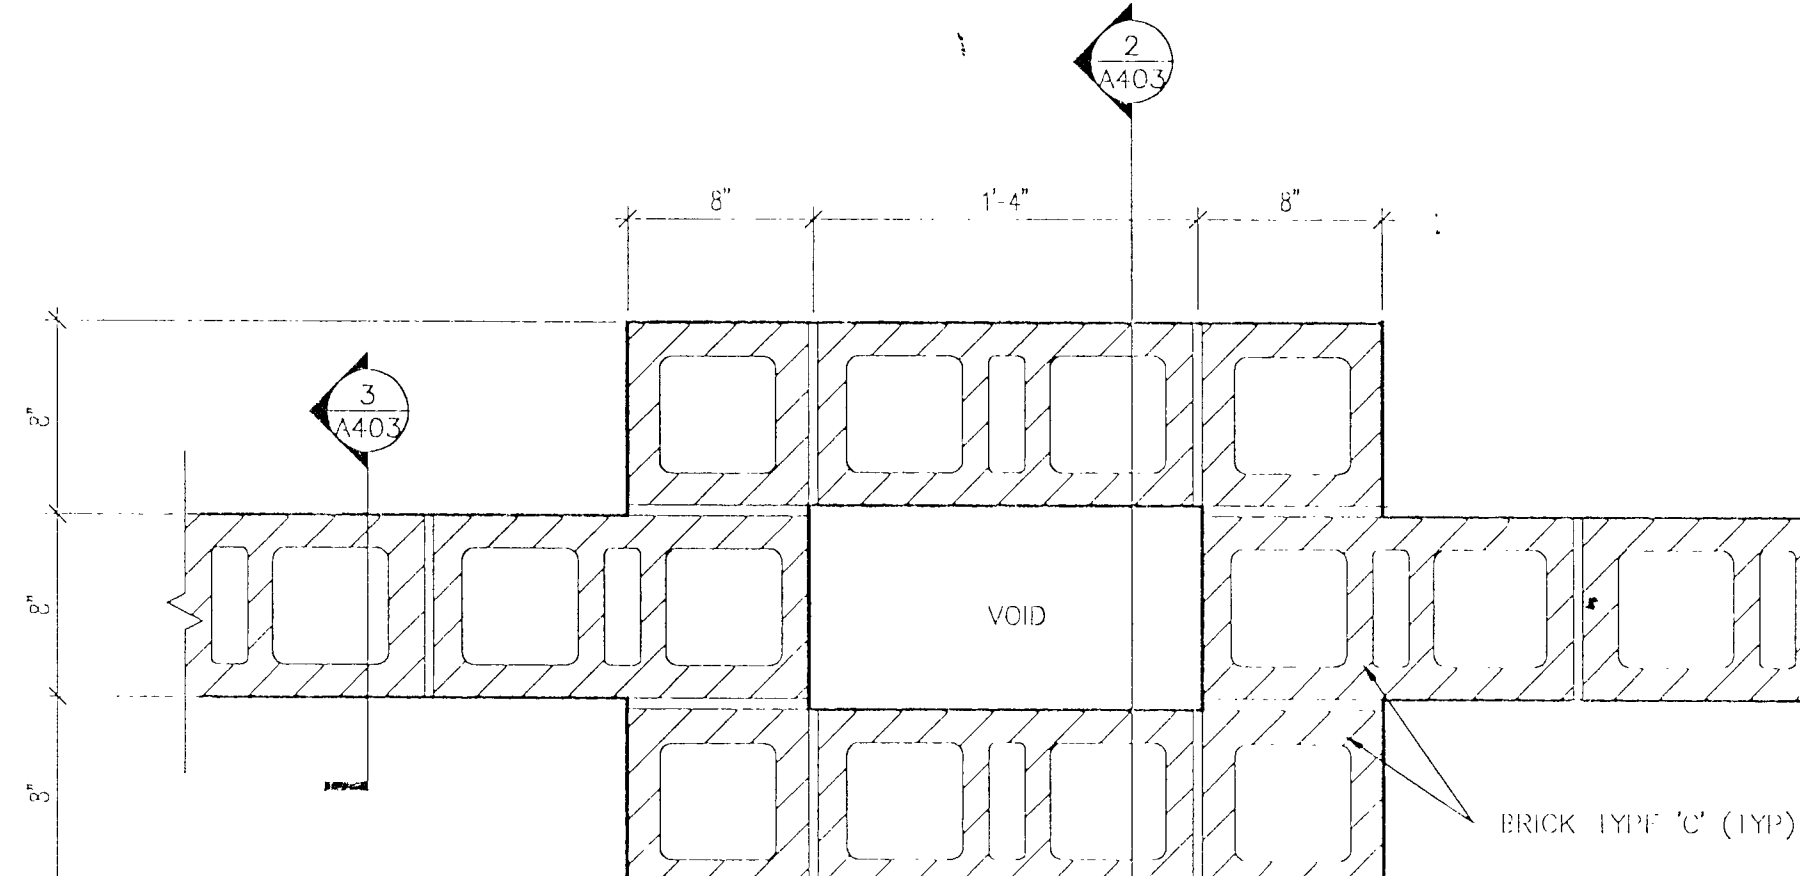

BRICK WALL FILASTER PLAN

SCALE: 1 1/2" = 1'-0"



4
A601

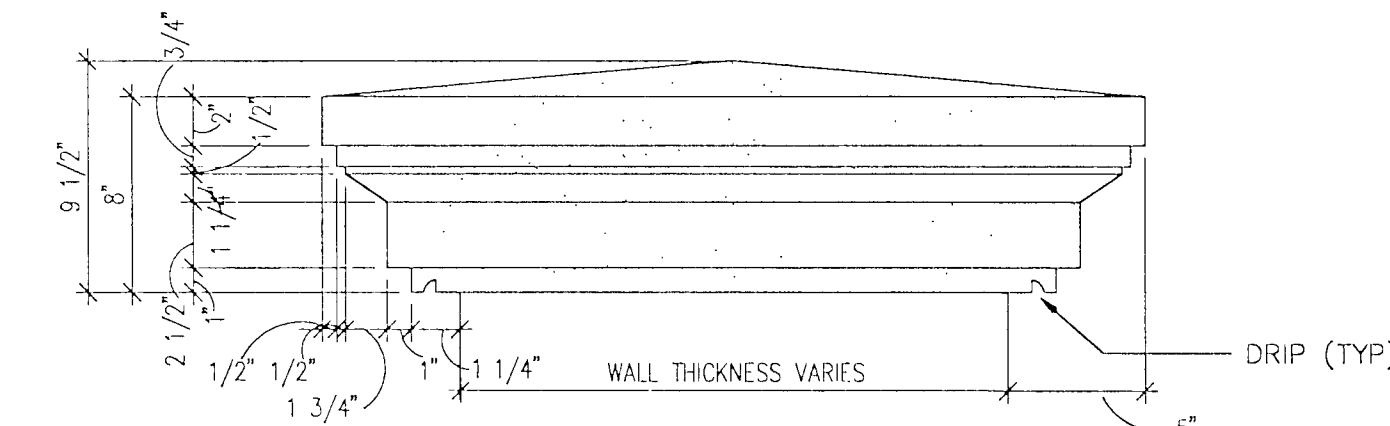

TYPICAL COPING PROFILE

SCALE: 1 1/2" = 1'-0"









3
A601

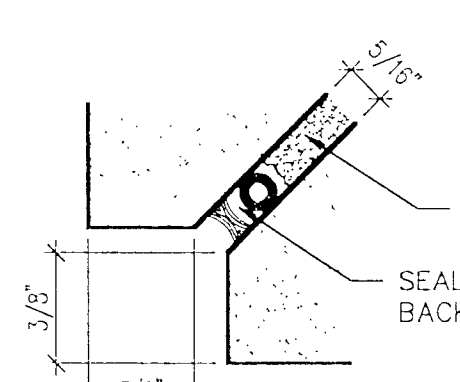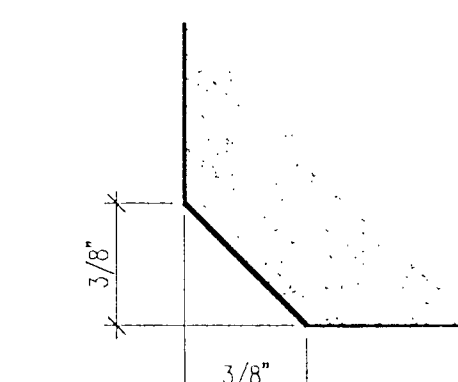

TYPICAL JOINT DETAILS

SCALE: NONE

2
A601

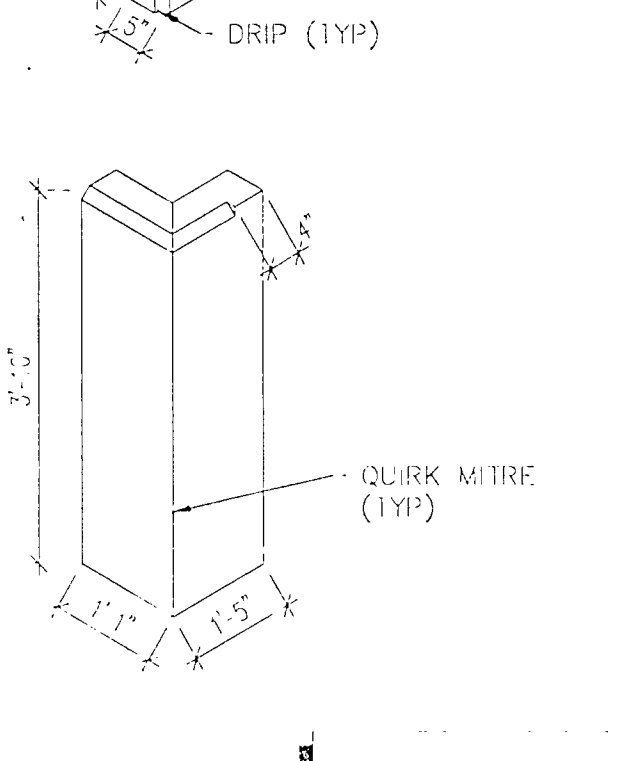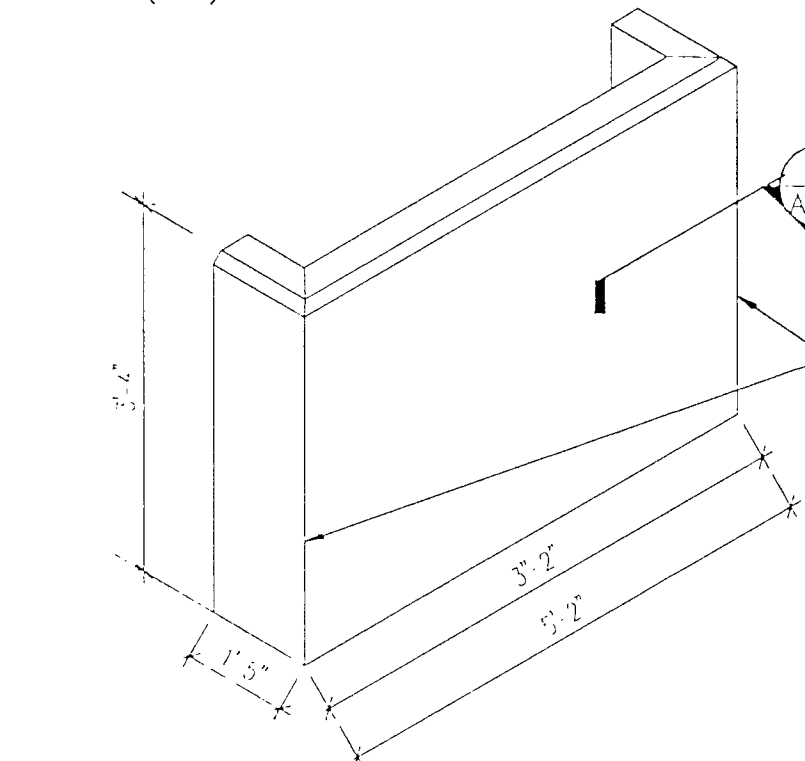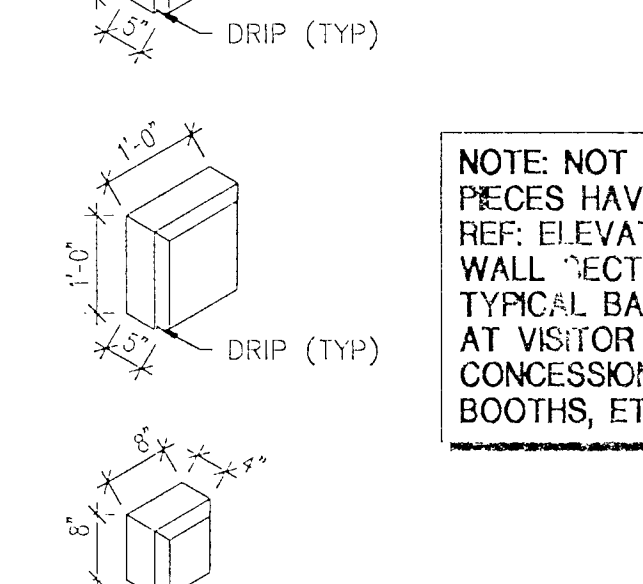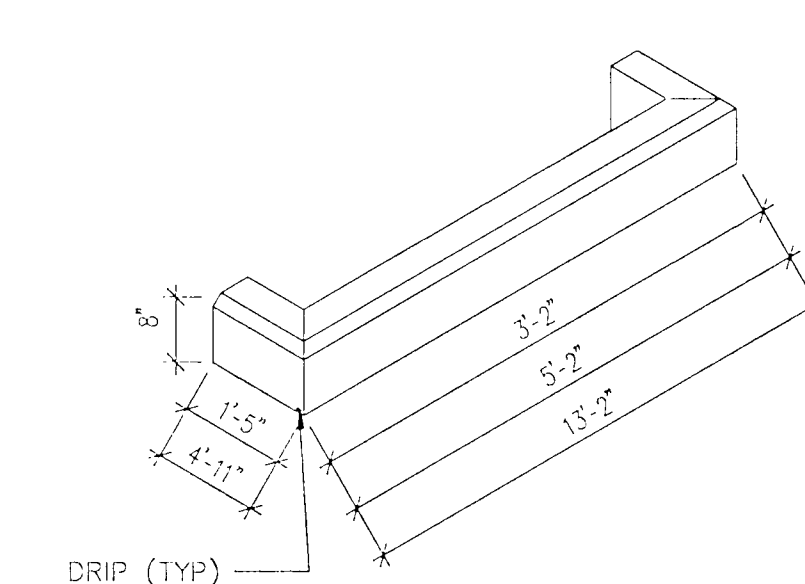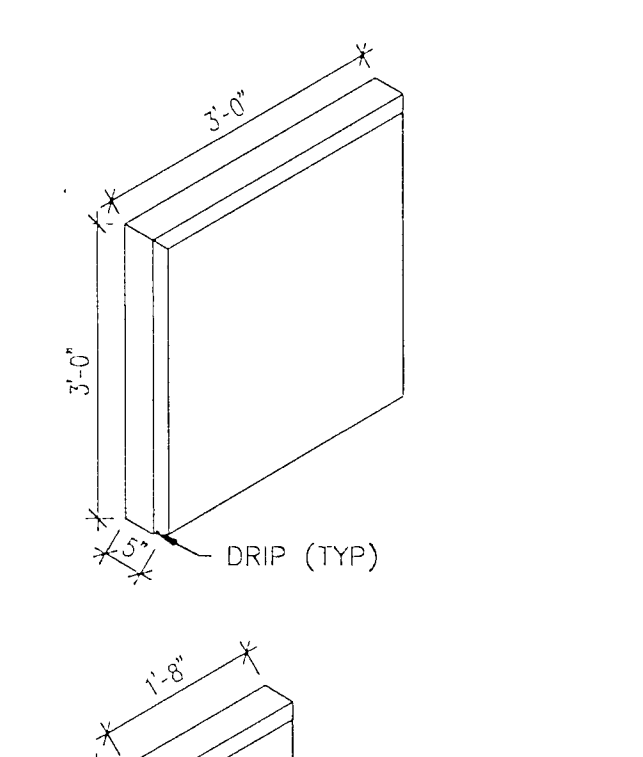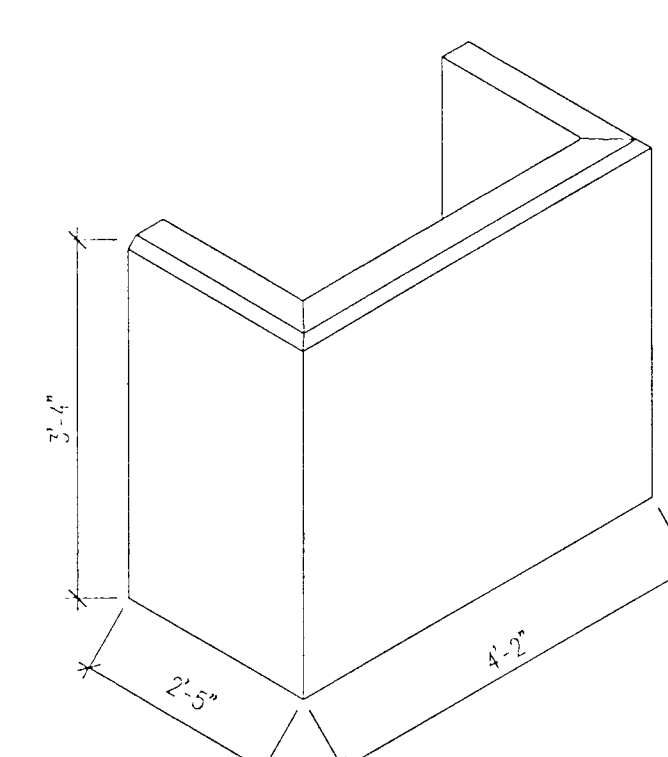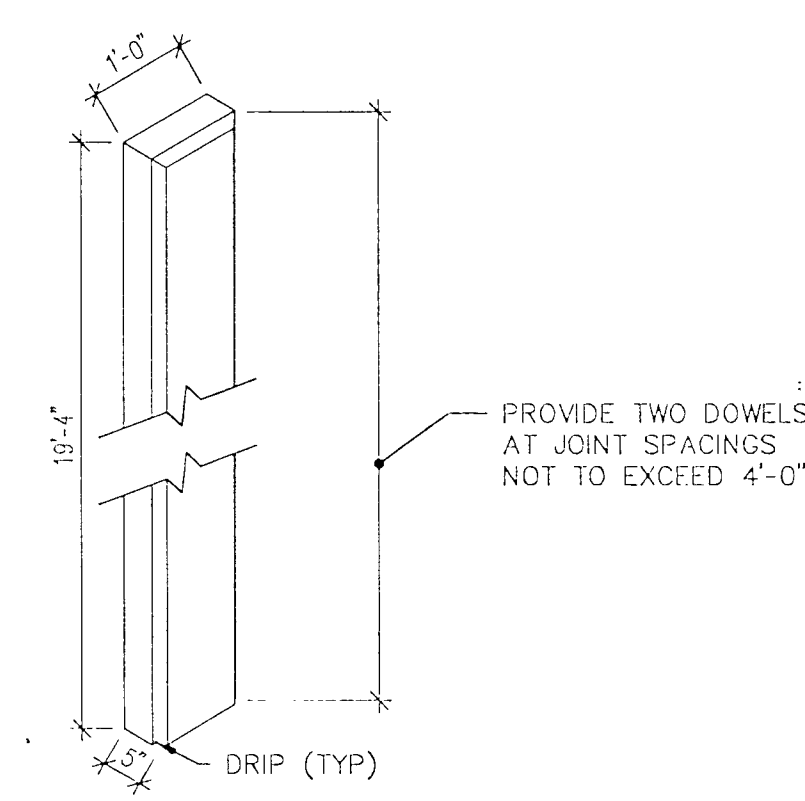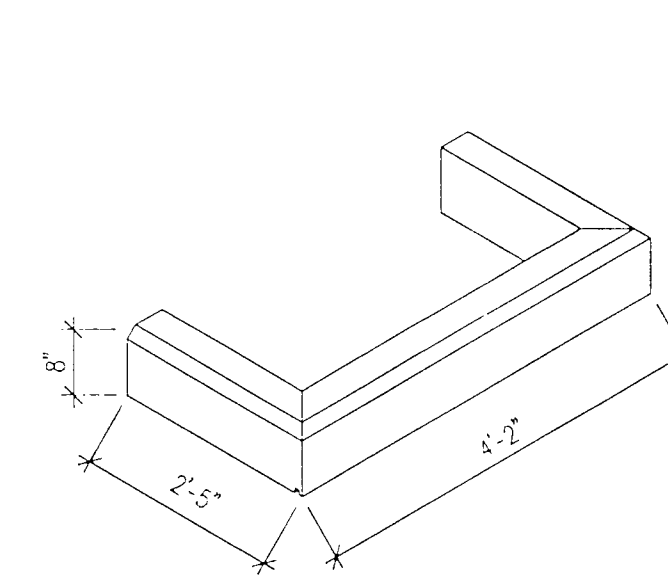


STONE DETAILS

SCALE: 1/2" = 1'-0"

1
A601

NOTE: ALL DIMENSIONS NOMINAL AND ARE TO BE VERIFIED IN FIELD.

NOTE: ALL PIECES TO BE
ARCHITECTURAL PRECAST
CONCRETE BASE BID.
LIMESTONE ALTERNATE.

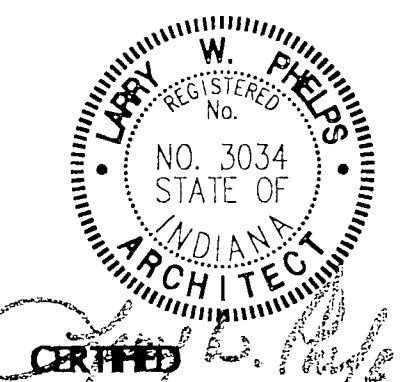

THE ODLE MCGUIRE & SHOOK CORPORATION
ARCHITECTURE • ENGINEERING • LANDSCAPE ARCHITECTURE • INTERIOR DESIGN
8765 NORTH STATE ROAD 37, POST OFFICE BOX 2149, BLOOMINGTON, INDIANA 47402, 812/876-2020
8275 ALISON POINTE TRAIL, POST OFFICE BOX 5426, INDIANAPOLIS, INDIANA 46250, 317/842-0000


REVISIONS

© Copyright 1984 by THE ODLE MCGUIRE & SHOOK CORPORATION. Copyright includes architectural work, building design, plans of drawings, and specifications. Architectural work is the result of an original design and is the property of THE ODLE MCGUIRE & SHOOK CORPORATION. Reproduction without written permission is prohibited.

MICHIGAN CITY SPORTS COMPLEX
AMES FIELD
MICHIGAN CITY, INDIANA

PROJECT NO. 93052
DATE MAY 31, 1984
drawn by: MR/MCW
checked by: GJ

A601
PLAN DETAILS

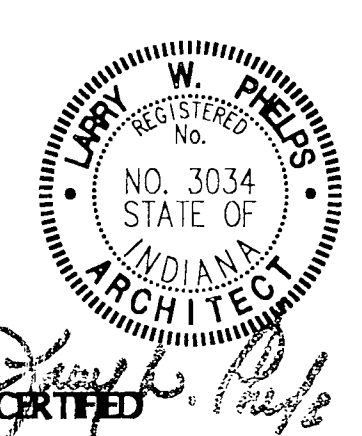

THE ODLE MCGUIRE & SHOOK CORPORATION
ARCHITECTURE • ENGINEERING • LANDSCAPE ARCHITECTURE • INTERIOR DESIGN
8765 NORTH STATE ROAD 37, POST OFFICE BOX 2149, BLOOMINGTON, INDIANA 47402, 812/676-2020
8275 ALLISON POINTE TRAIL, POST OFFICE BOX 50428, INDIANAPOLIS, INDIANA 46250, 317/642-0000


REVISIONS

© Copyright 1994 by THE ODLE MCGUIRE & SHOOK CORPORATION. Copyright includes architectural work, building design, plans or drawings, and specifications. Architectural work is the result of form as well as the creative mind and composition of space and elements in the design. Reproduction without written permission is prohibited.

MICHIGAN CITY SPORTS COMPLEX
AMES FIELD
MICHIGAN CITY, INDIANA

PROJECT NO. 93052
DATE: MAY 31, 1994
drawn by: MRM
checked by: GJ


A602
PLAN DETAILS

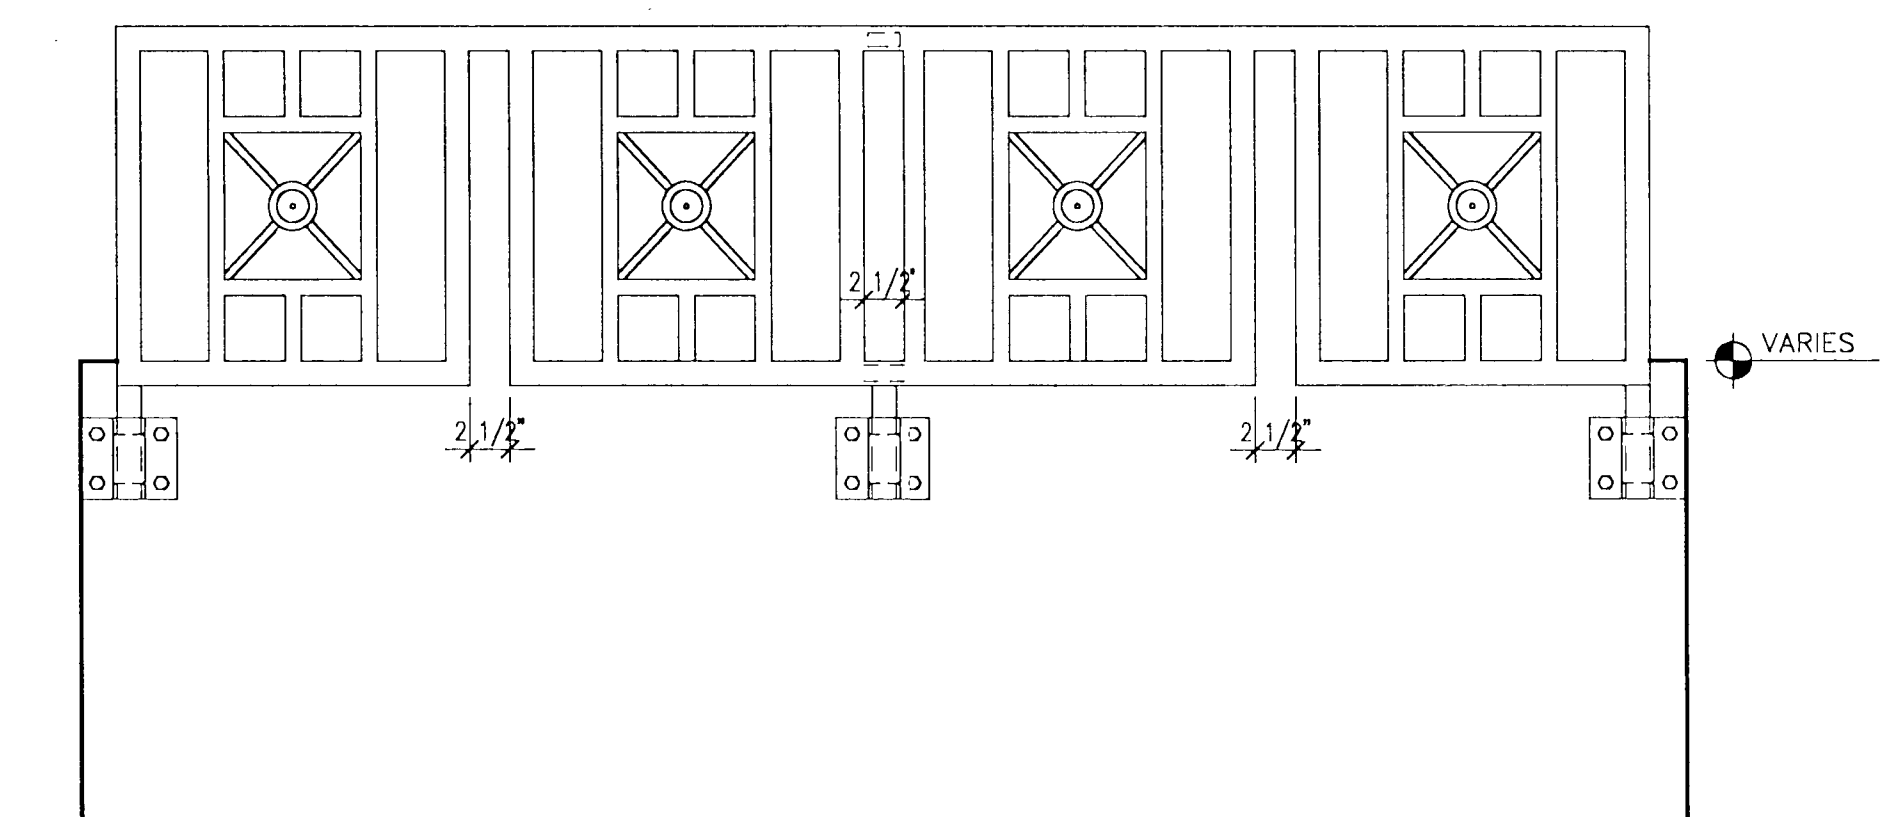

RAILING ELEVATION

SCALE: 1" = 1'-0"

TOP/PRECAST CONC. PANEL (TYP)

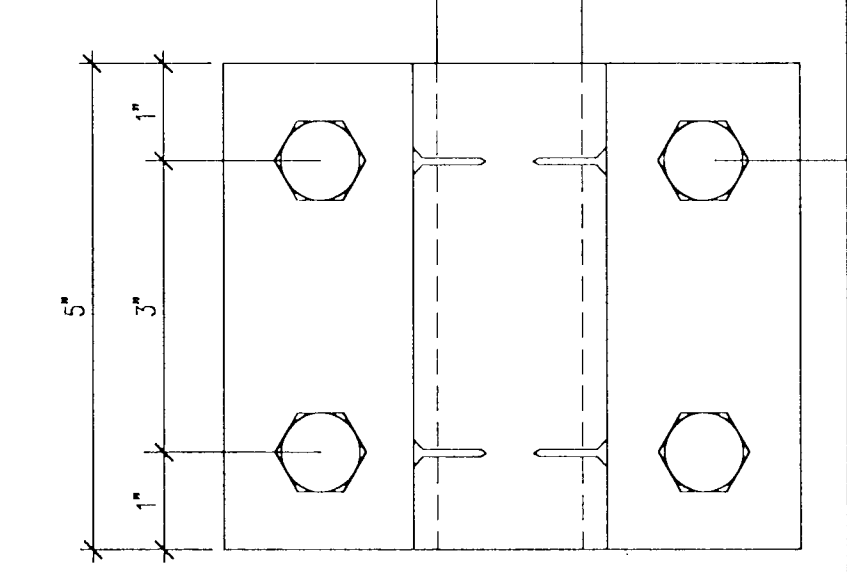

ELEVATION

S.S. EXPANSION ANCHORS 2 PER SIDE

1 1/2" x 1 1/2" ALUM. POST W/ BOTTOM CLOSURE PLATE

1/4" ALUM. POST BRACKET SIZE SLEEVE FOR SNUG FIT TO POST - NO BOTTOM PLATE

EDGE OF PRECAST STAIR TREAD


PLAN

COUNTERSUNK S.S. VANDAL-PROOF FASTENERS - 2 PER SIDE

EDGE OF PRECAST

POST BRACKET DETAIL

SCALE: HALF FULL

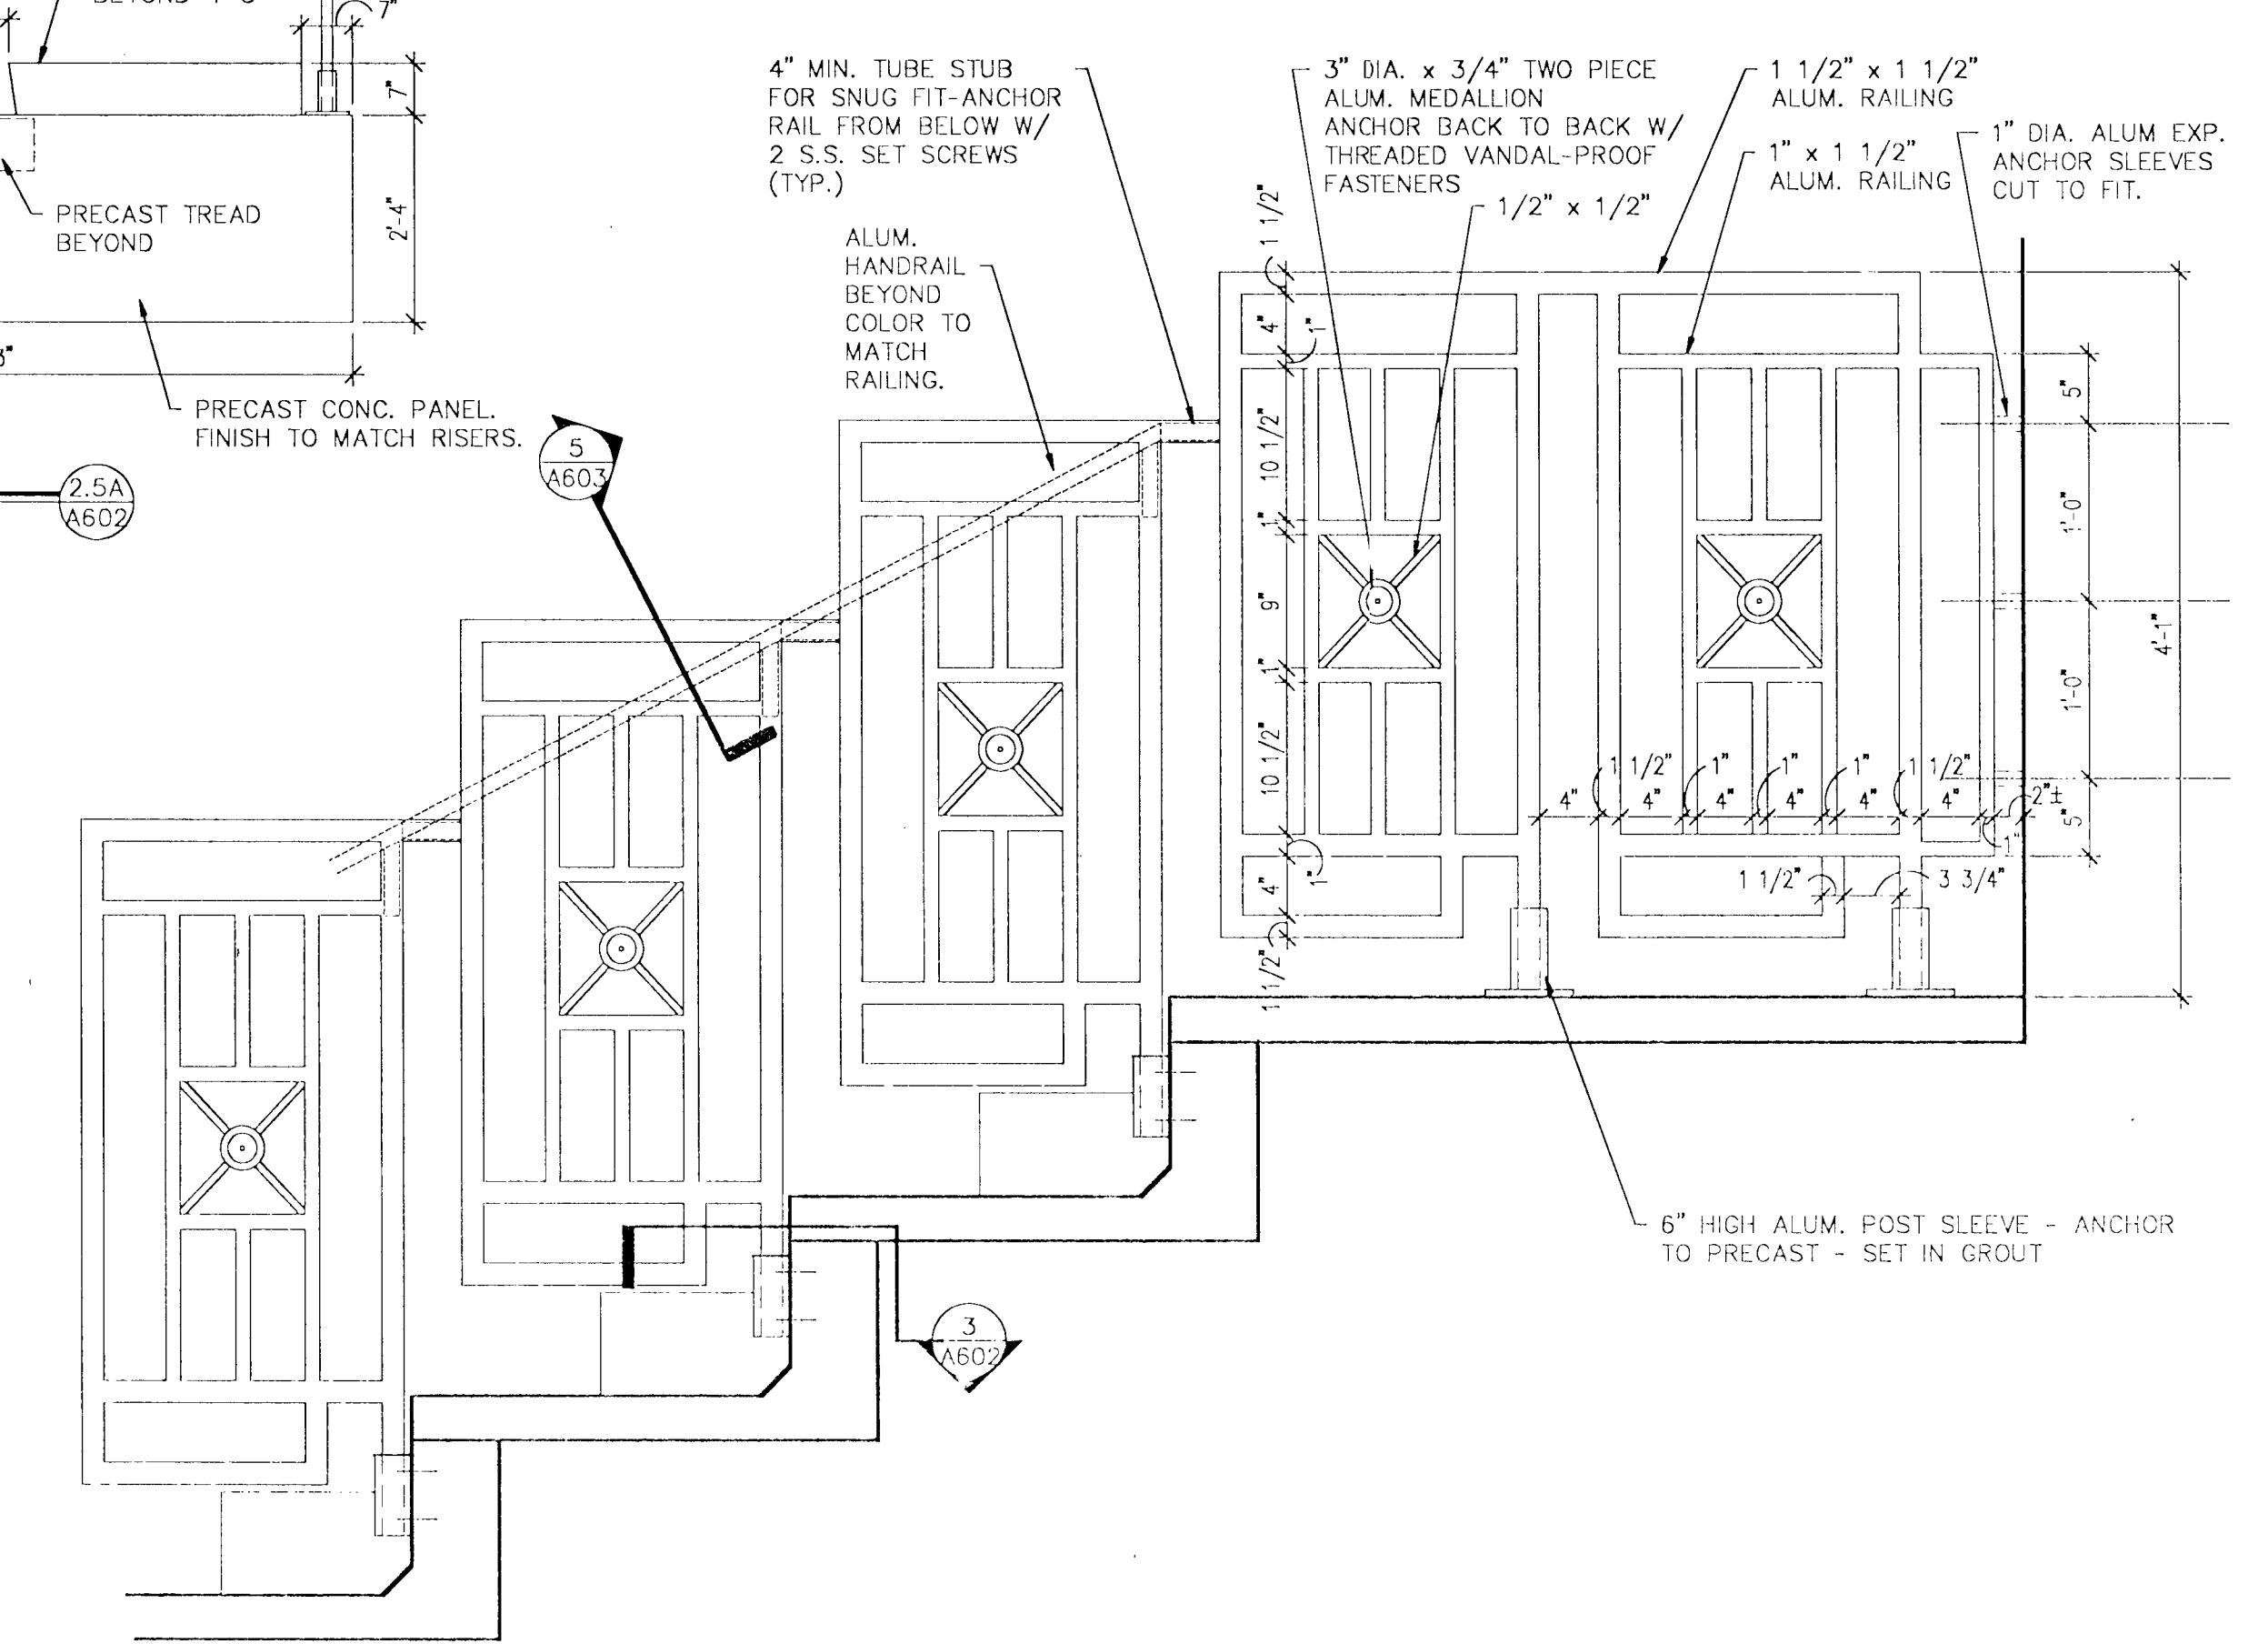


RAILING ELEVATION

SCALE: 1" = 1'-0"


RAILING ELEVATION

SCALE: 1" = 1'-0"

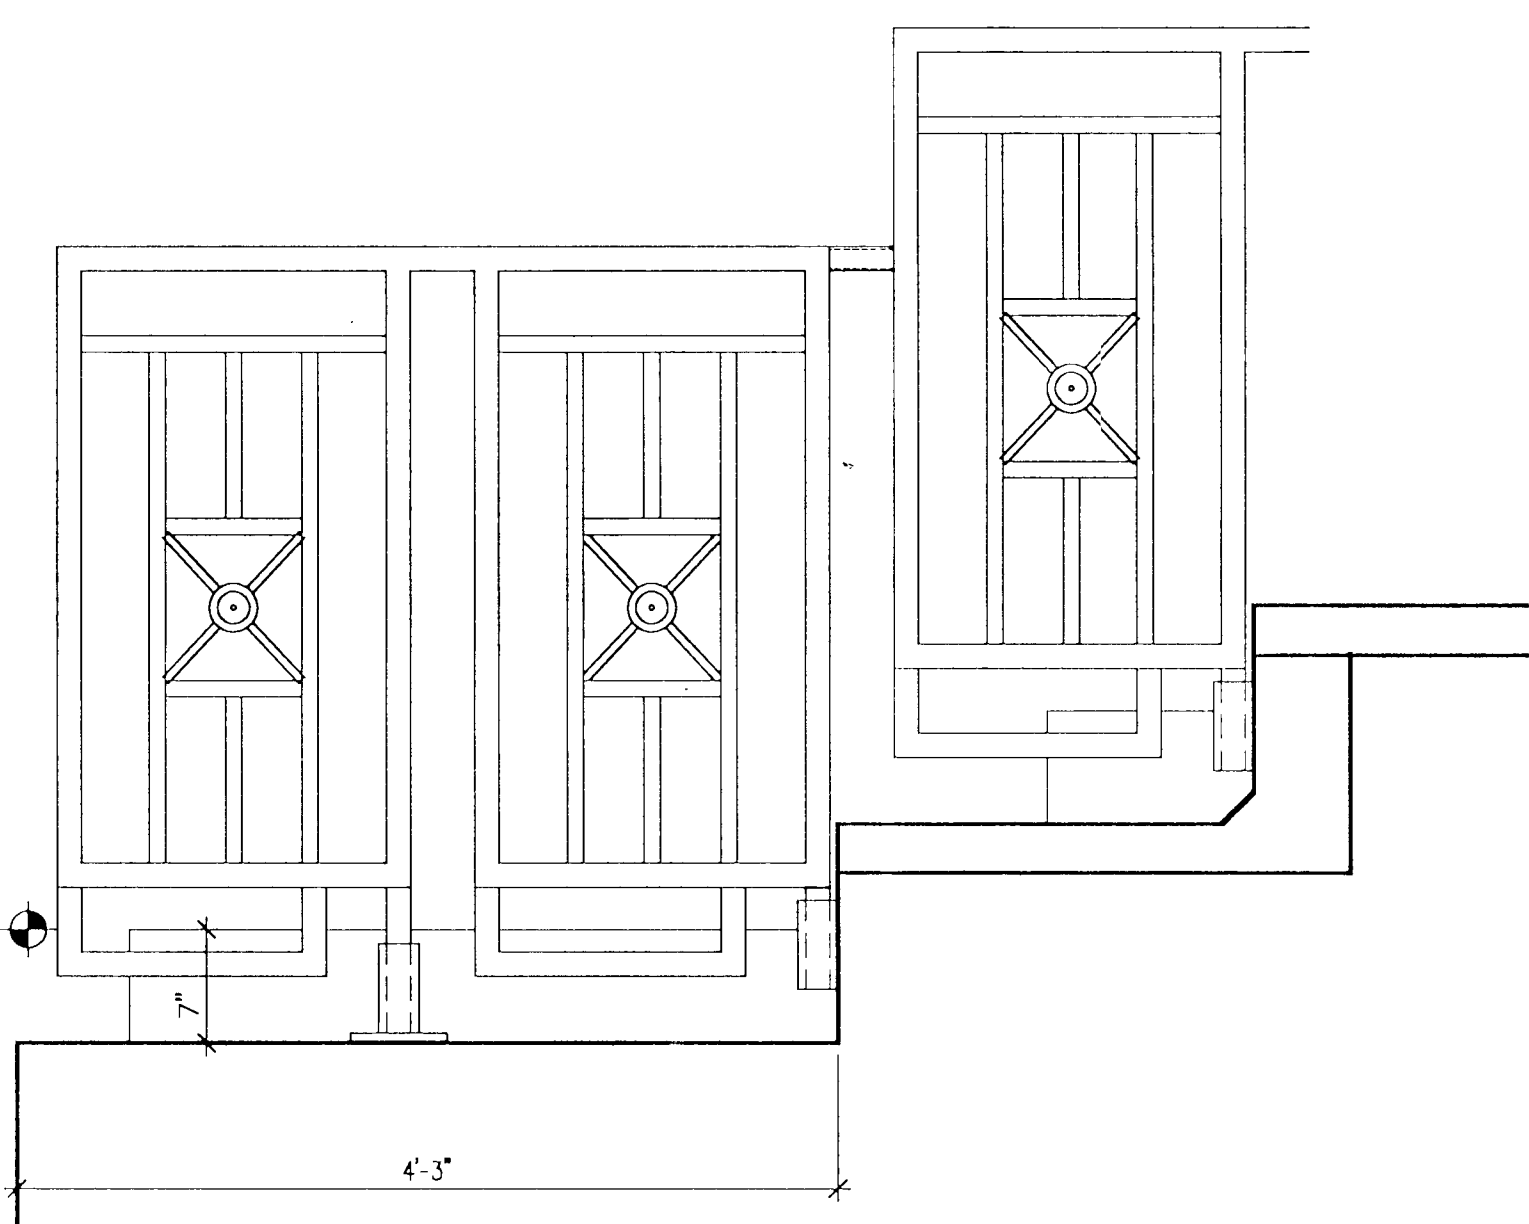

RAILING ELEVATION

SCALE: 1" = 1'-0"

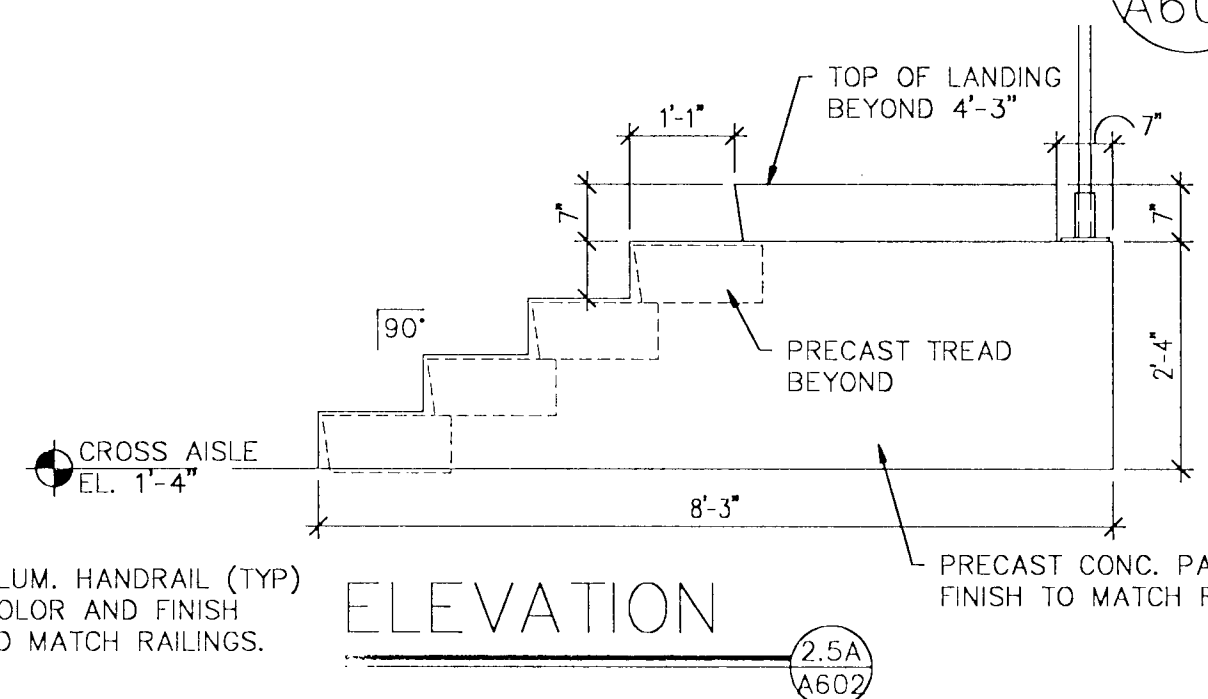

ELEVATION

SCALE: 1/2" = 1'-0"

CROSS AISLE EL. 1'-4"

TOP OF LANDING BEYOND 4'-3"

PRECAST CONC. PANEL FINISH TO MATCH RISERS.

ALUM. HANDRAIL (TYP) COLOR AND FINISH TO MATCH RAILINGS.

PRECAST TREAD BEYOND

90°

8'-3"

2'-4"

2.5A A602

NOTE: PRECAST STAIR TREADS AT RAMPS A120A AND A122A TO BE SIMILAR BUT WITH A TREAD DEPTH OF 11" AND A RISE OF 7".

PRECAST TREAD (TYP)


GALVANIZED STEEL ANGLE STEEL PLATE IN PRECAST WALL

SEALANT AND BACKER ROD, ALL STAIR JOINTS (TYP)

2 A602


RAILING ELEVATION

SCALE: 1" = 1'-0"

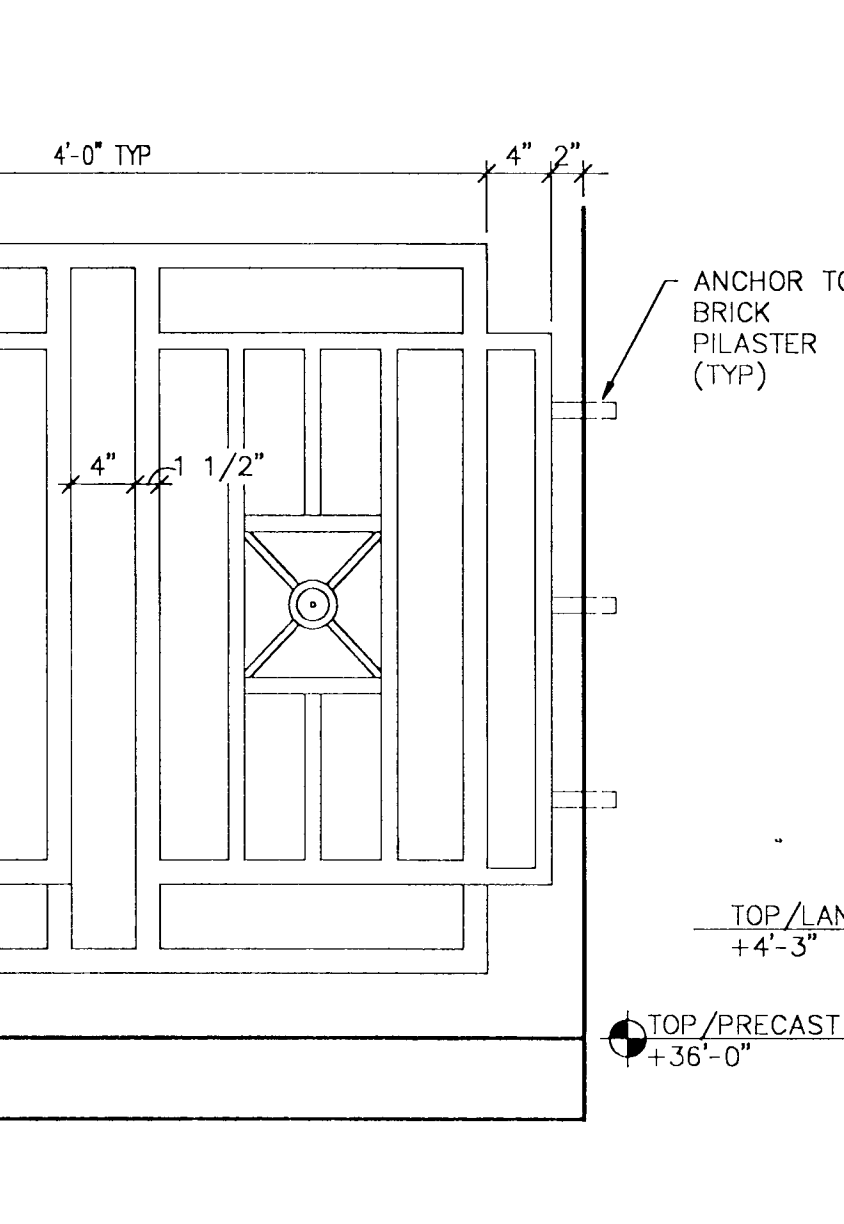

RAILING ELEVATION

SCALE: 1/2" = 1'-0"

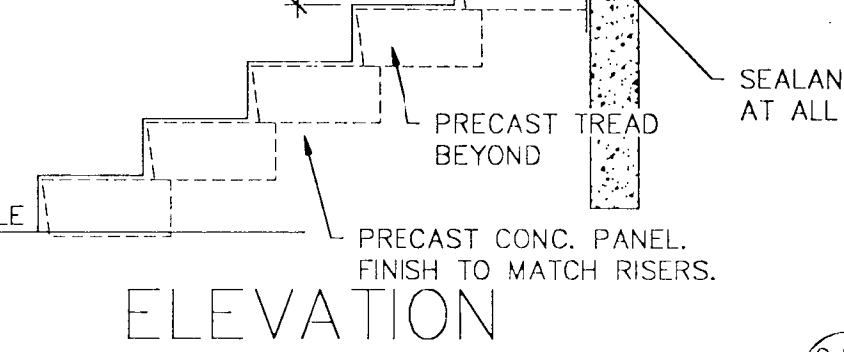

ELEVATION

SCALE: 1/2" = 1'-0"

CROSS AISLE EL. 1'-4"

TOP/STEP EL. 4'-3"

PRECAST TREAD BEYOND

PRECAST CONC. PANEL FINISH TO MATCH RISERS.

14 PANELS @ 4'-0" EA. + 4" BETWEEN EA. PANEL = 60'-4"

PANEL CONNECTIONS (TYP)

4'-0"

1 1/2"

1 1/2"

1 1/2"

1 1/2"

1 1/2"

1 1/2"


1 1/2"

1 1/2"

1 1/2"


RAILING ELEVATION

SCALE: 1" = 1'-0"

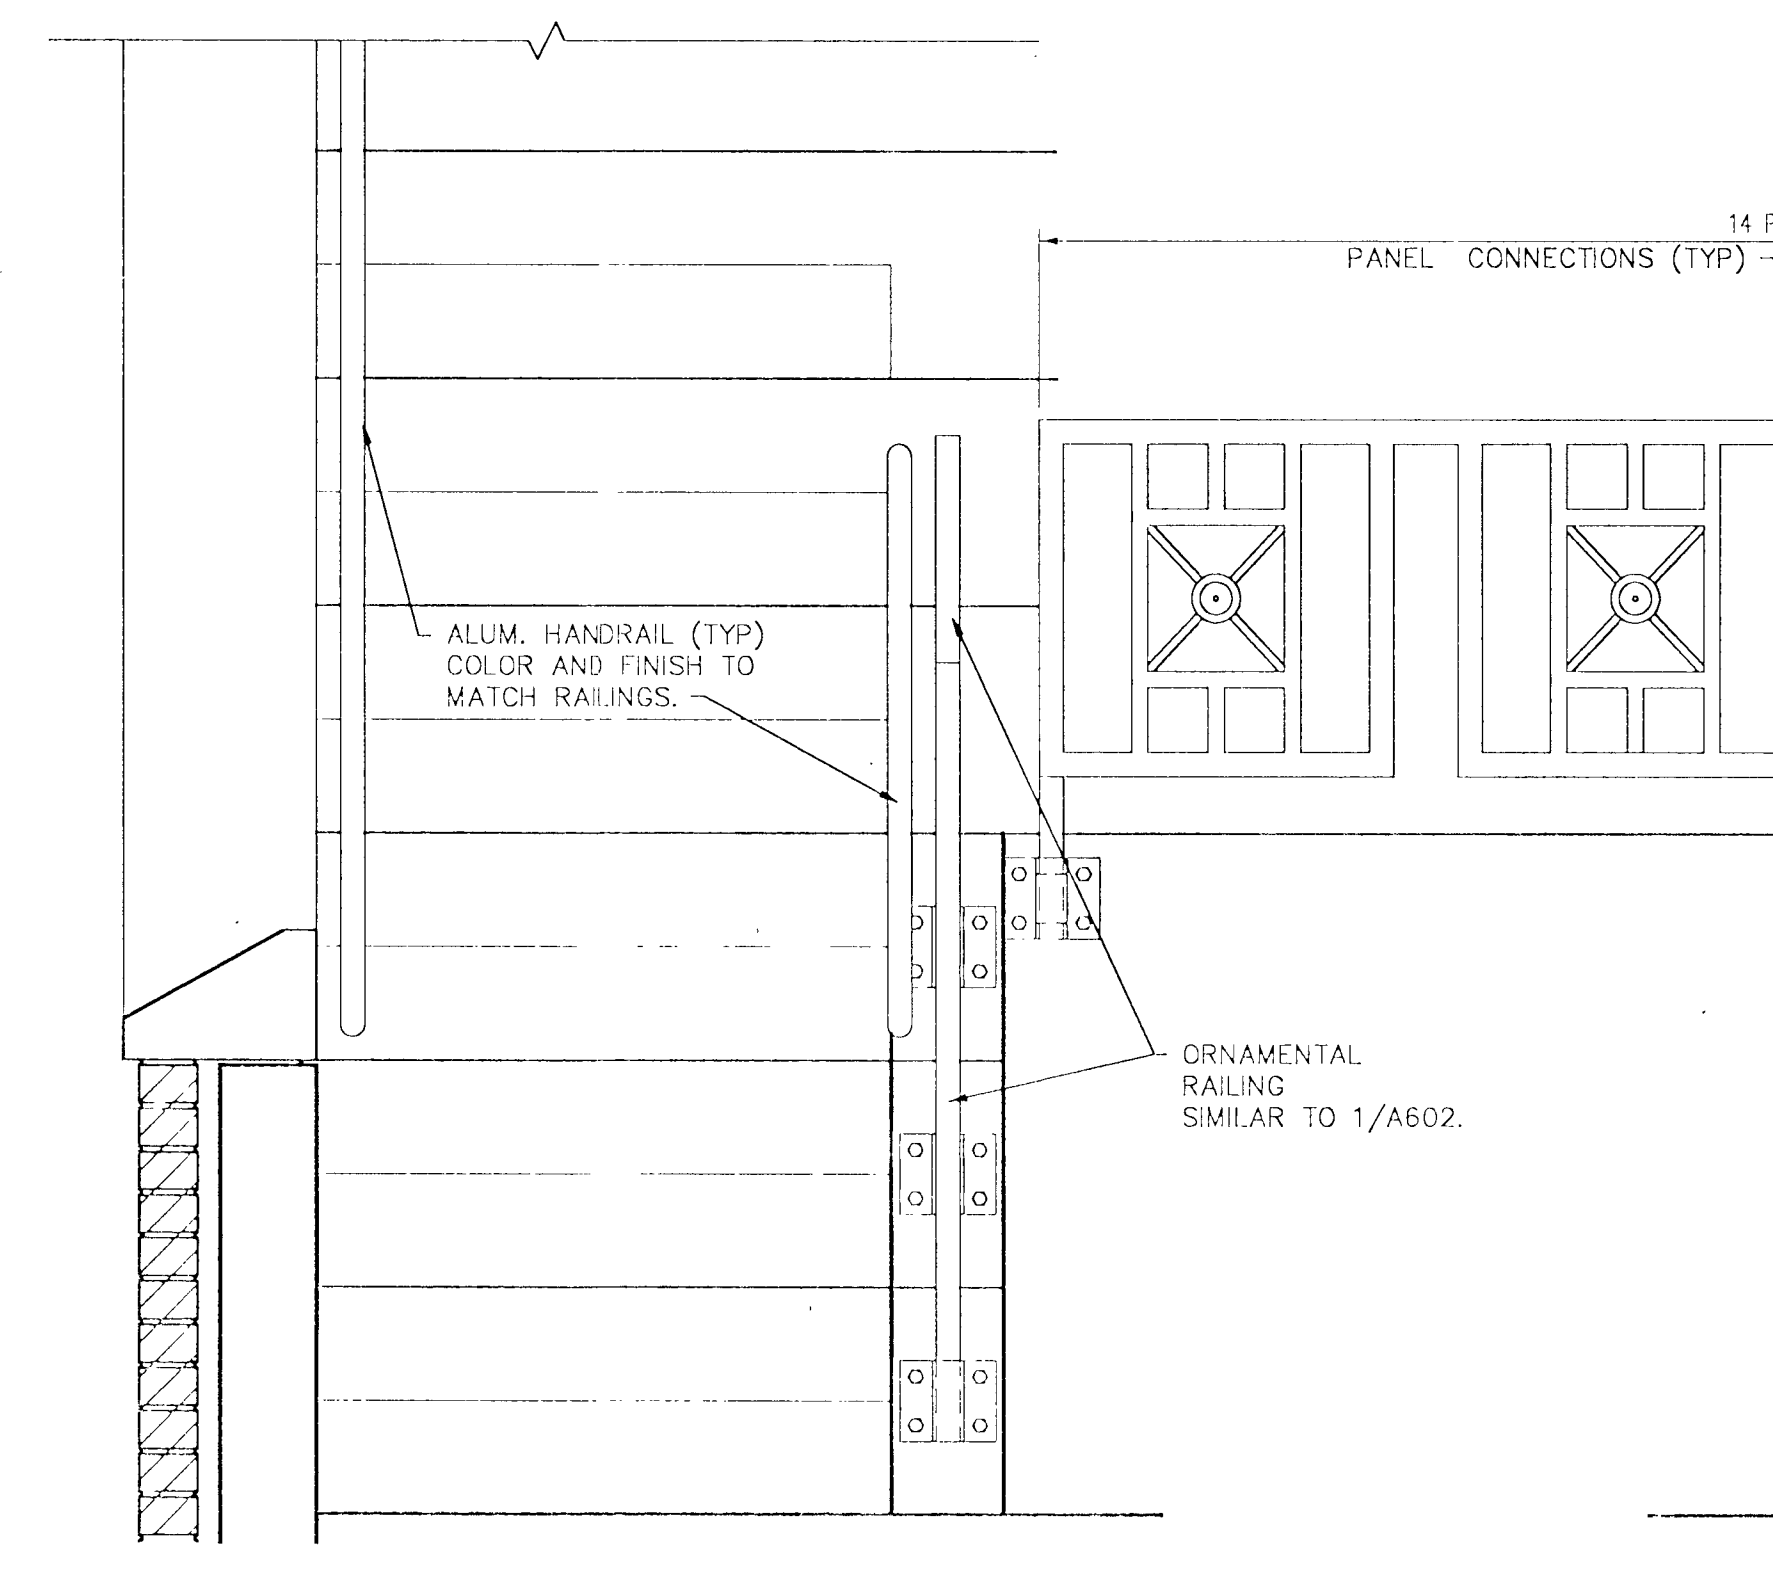


RAILING ELEVATION

SCALE: 1" = 1'-0"

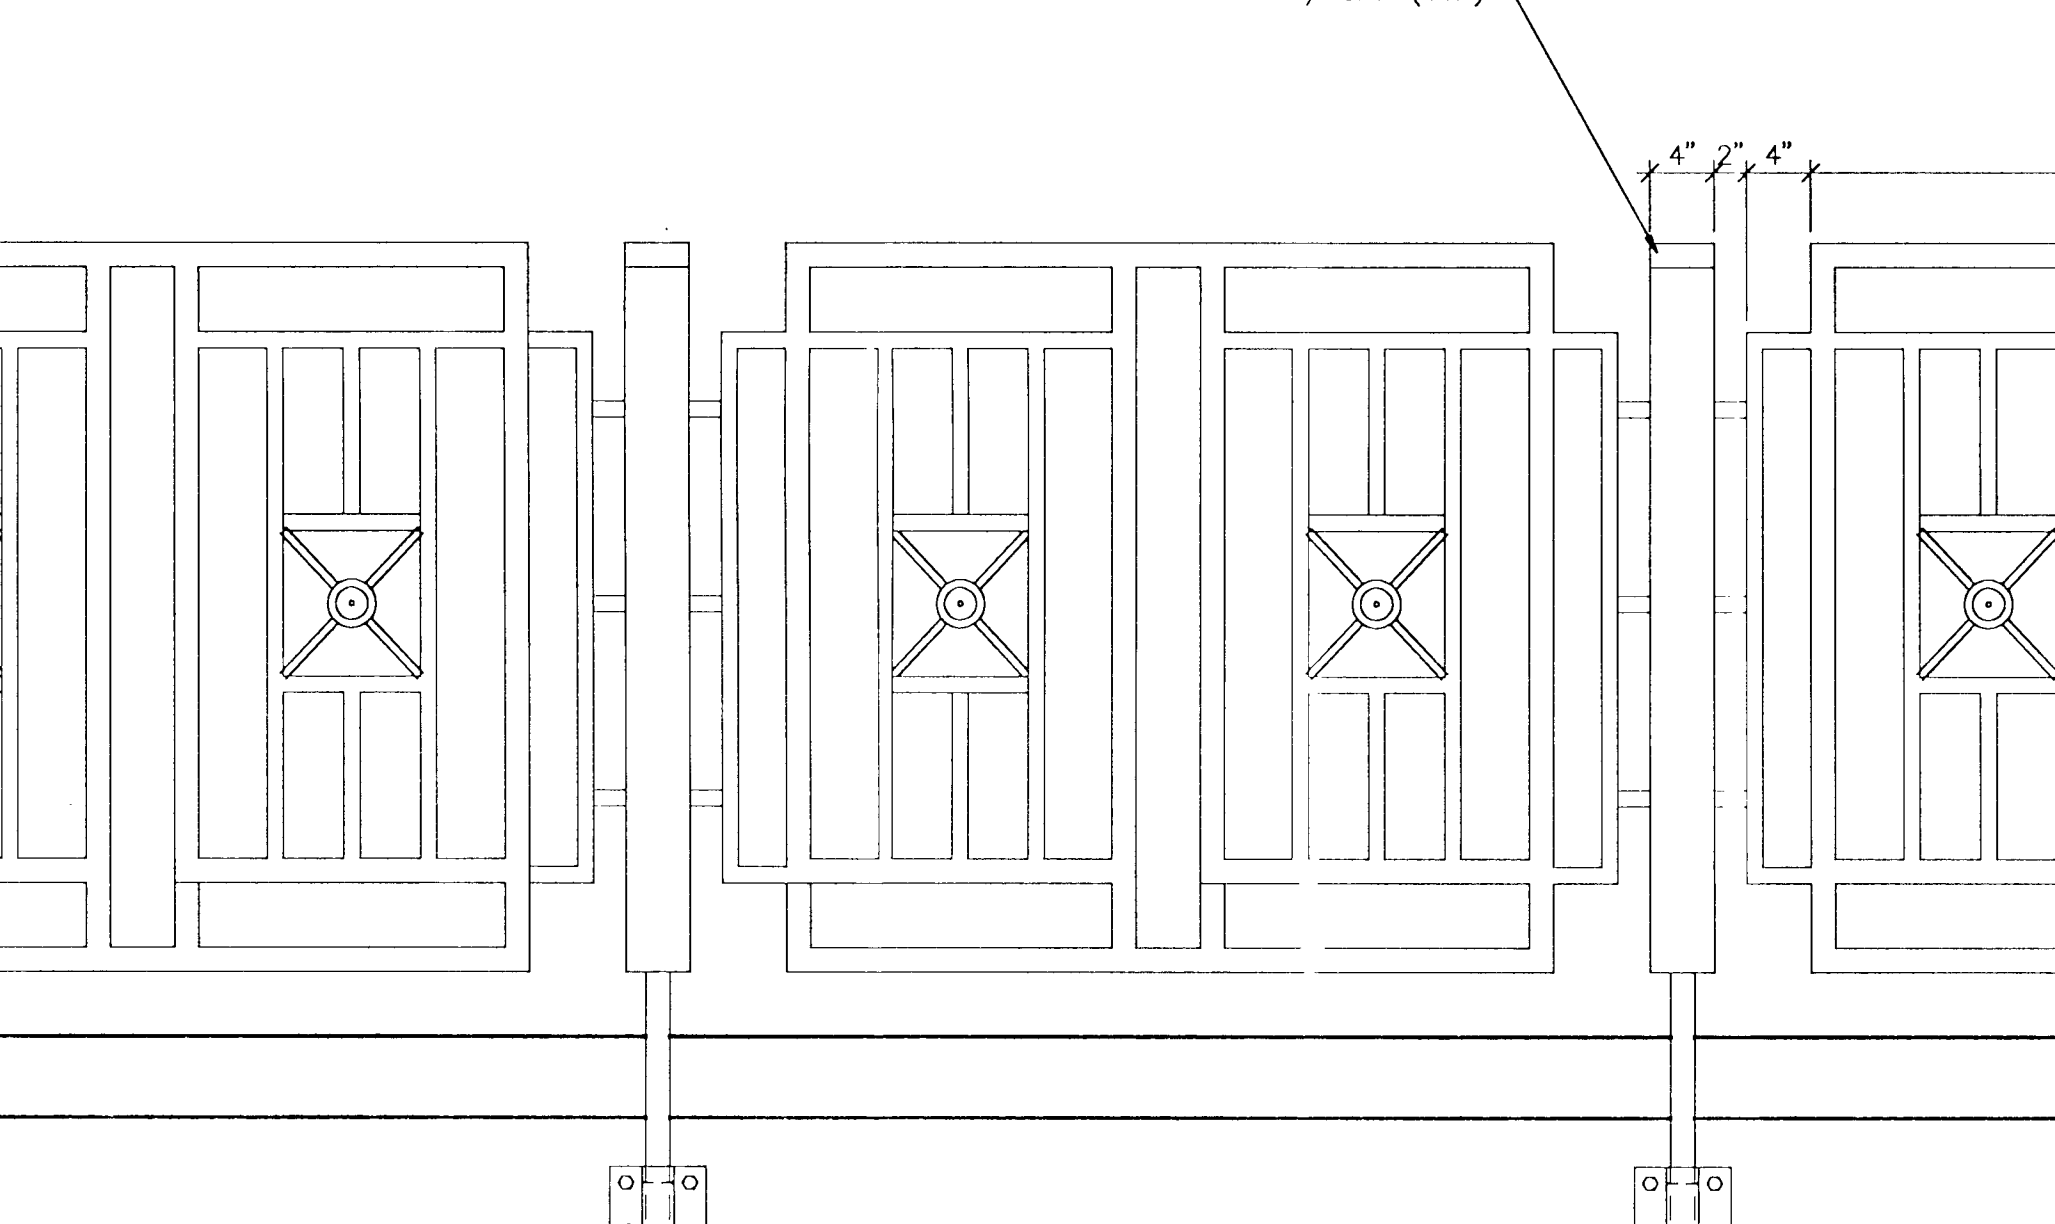

RAILING ELEVATION

SCALE: 1" = 1'-0"

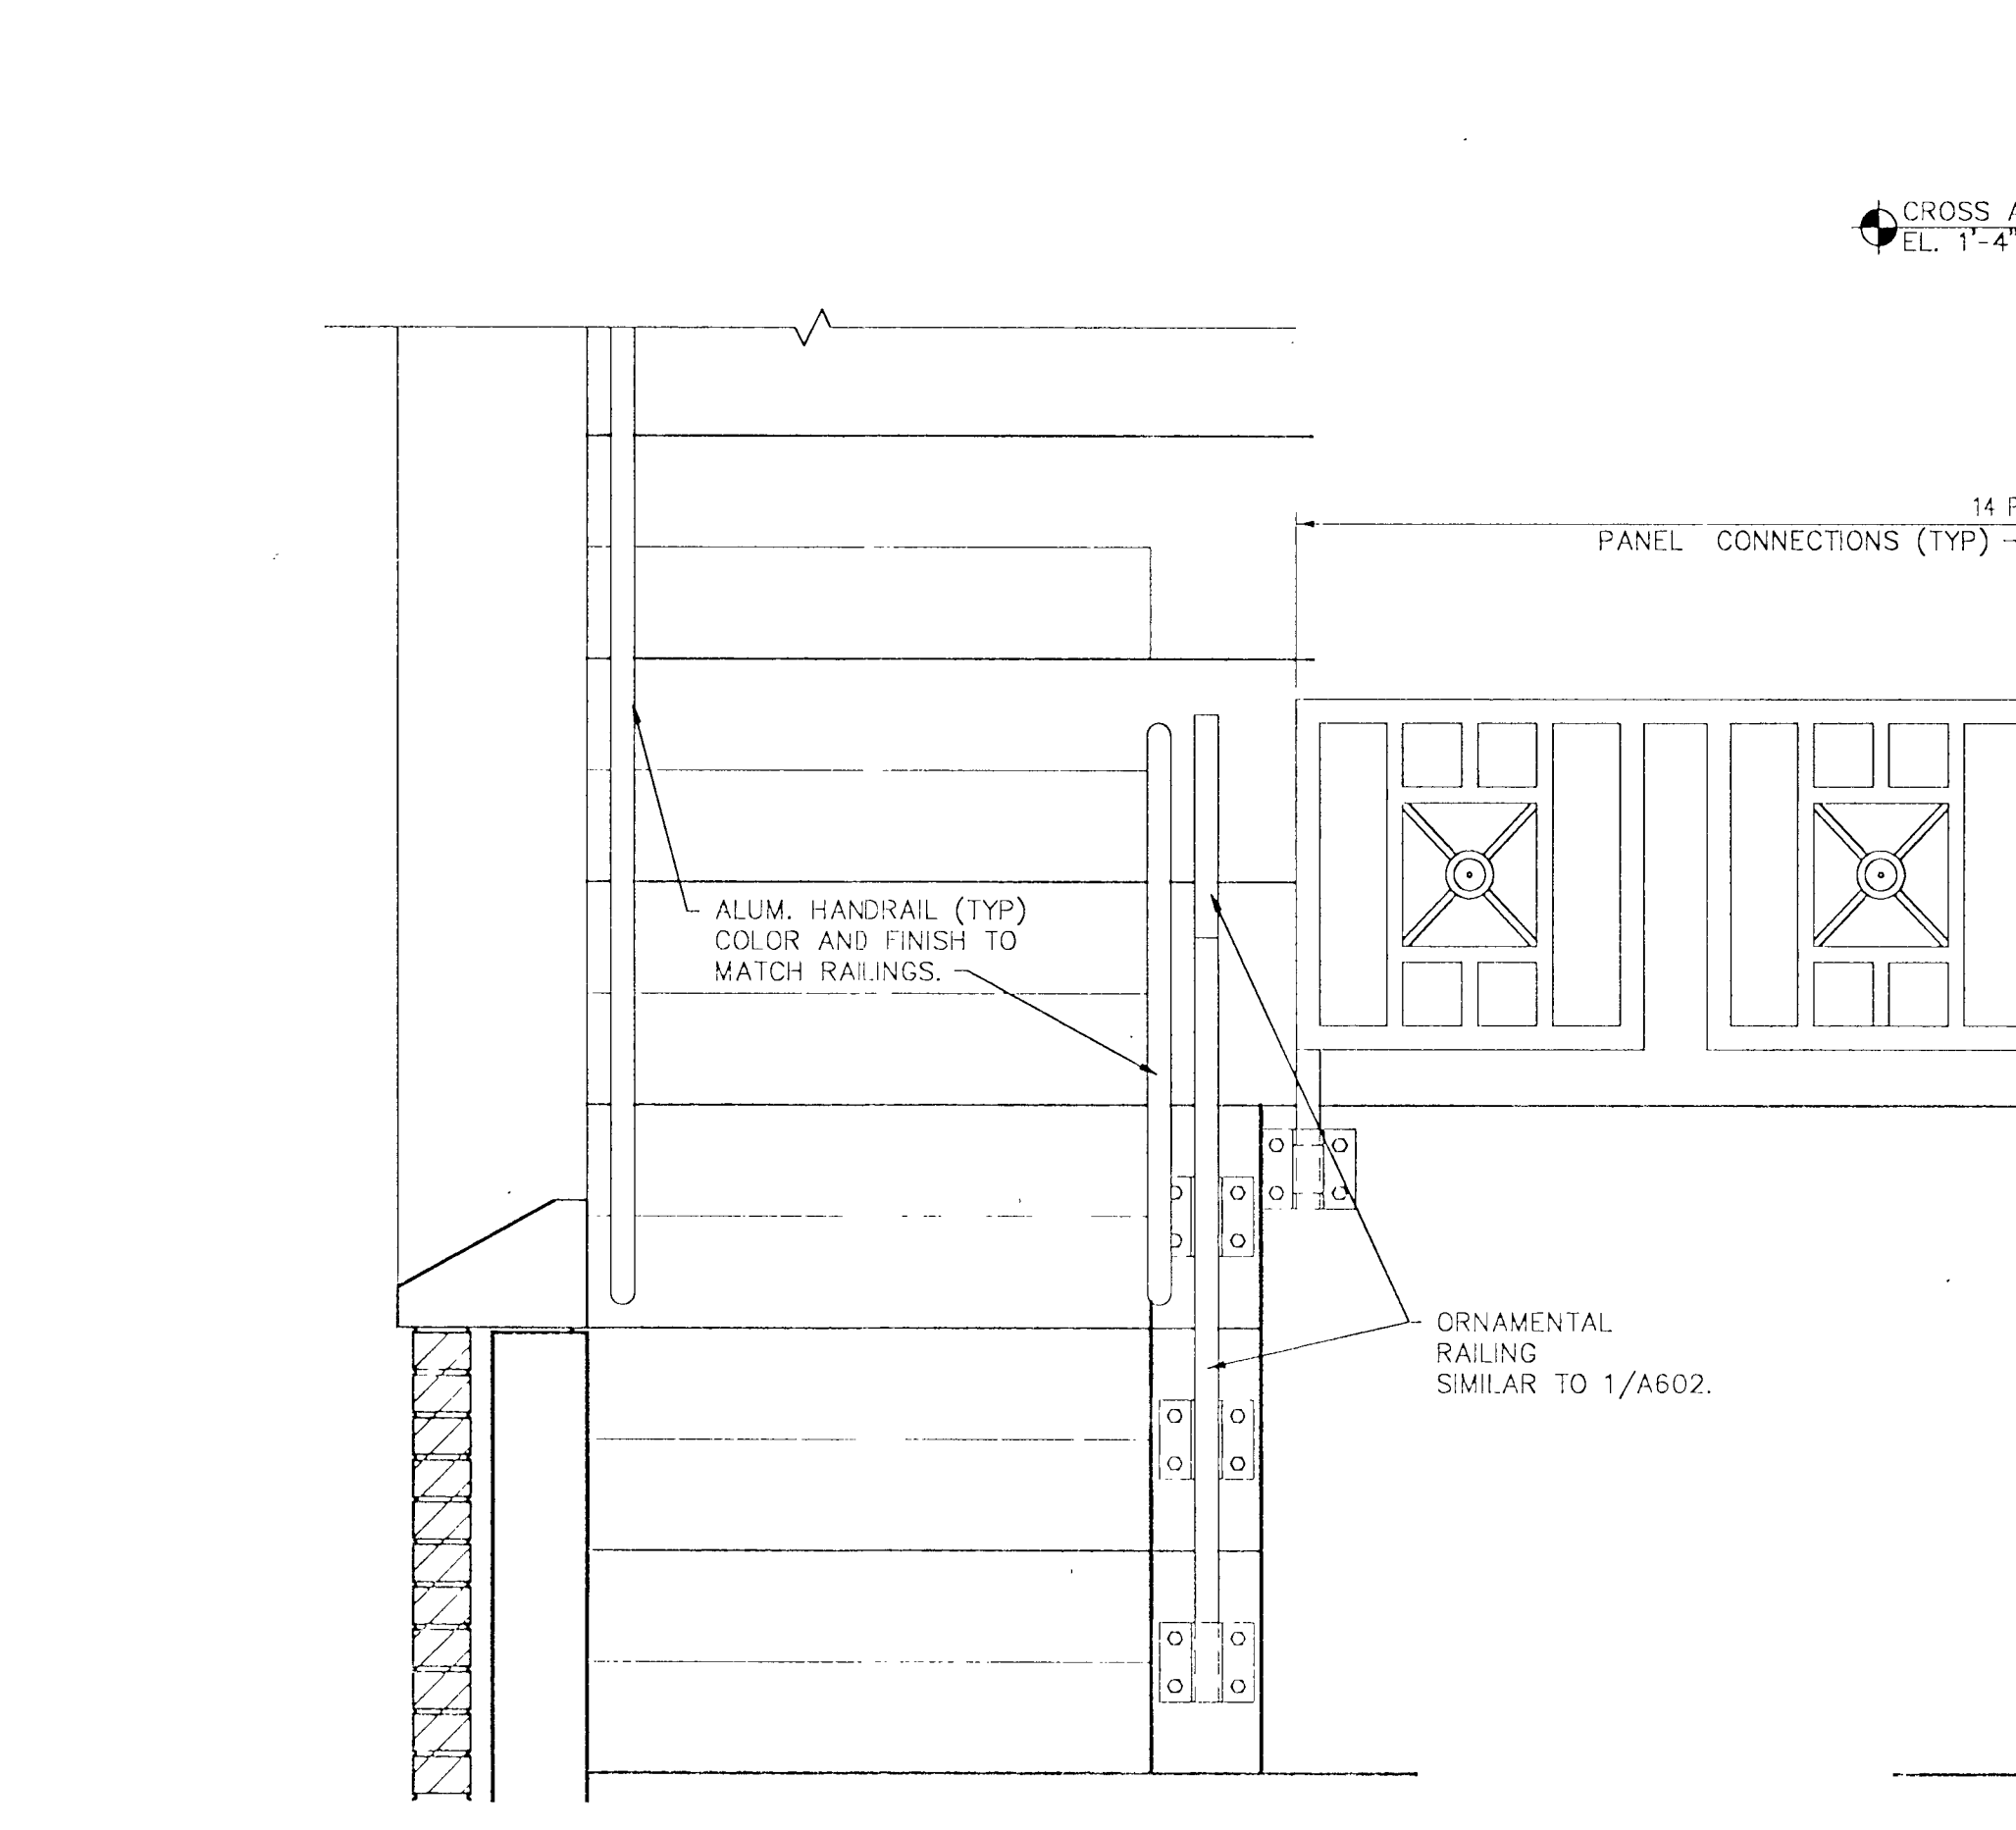


RAILING ELEVATION

SCALE: 1" = 1'-0"


SCALE: 1" = 1'-0"

F:\ARCHITECT\3052A\3052A602 05-27-94 20:34:28

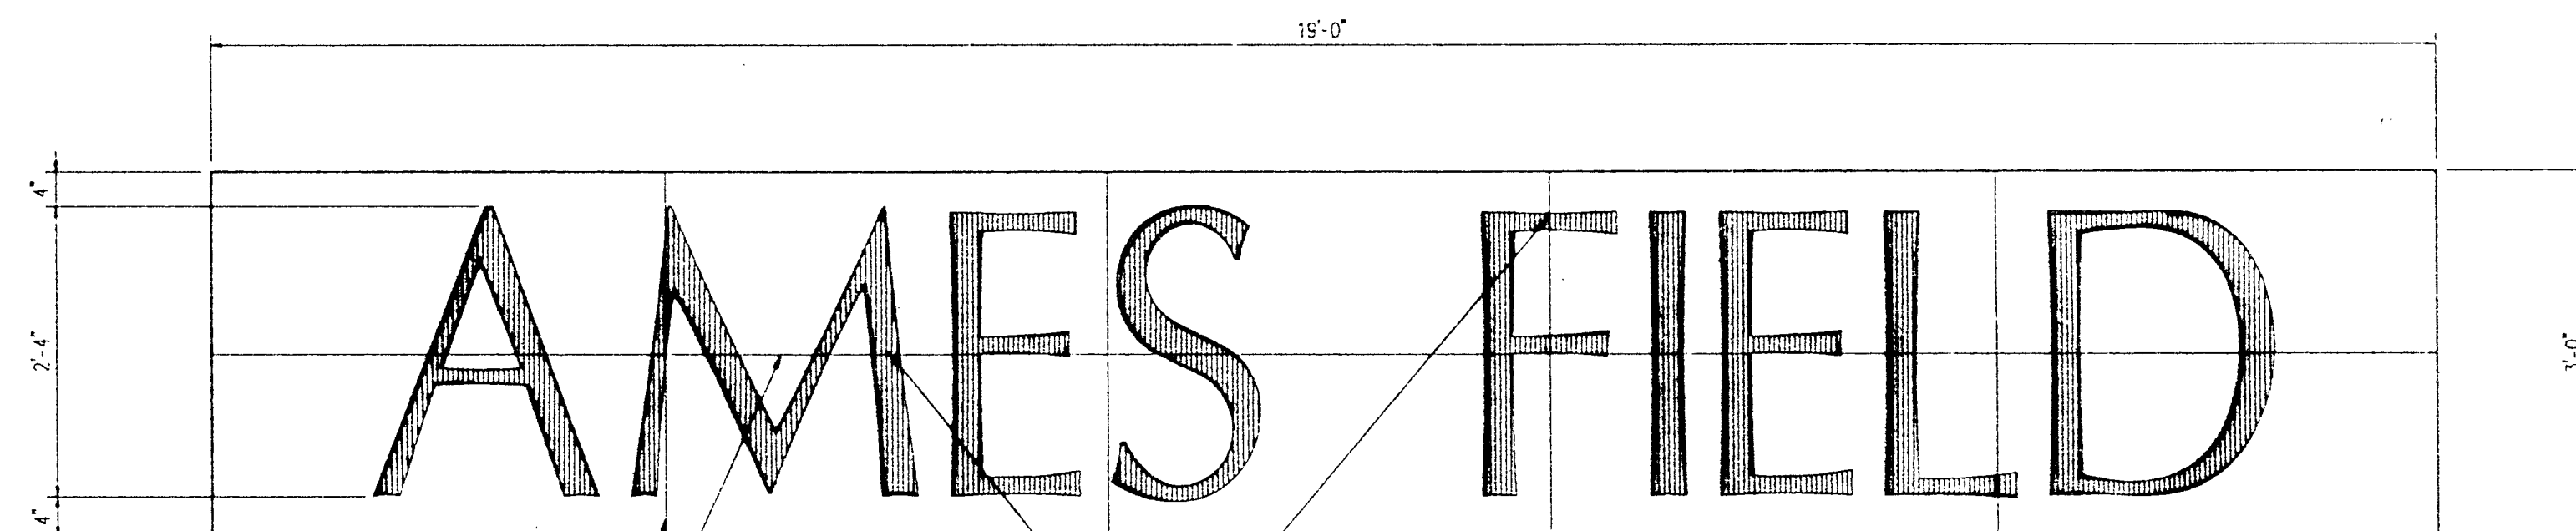


MORTAR JOINTS

STAIN JOINTS TO MATCH LETTERS, TYPICAL

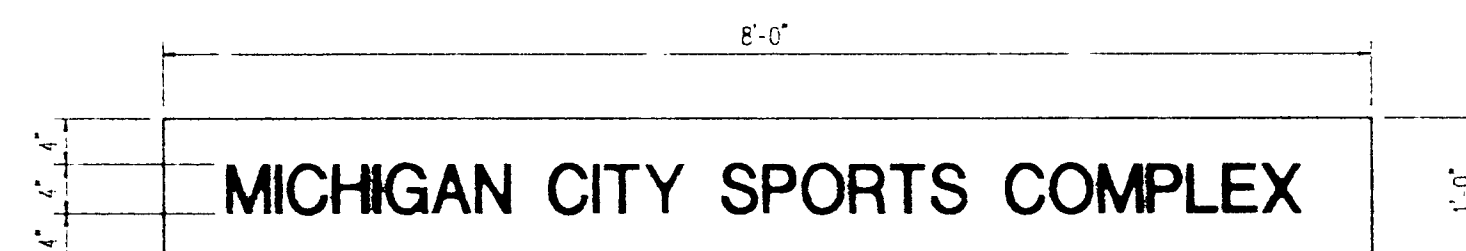


MICHIGAN CITY SPORTS COMPLEX

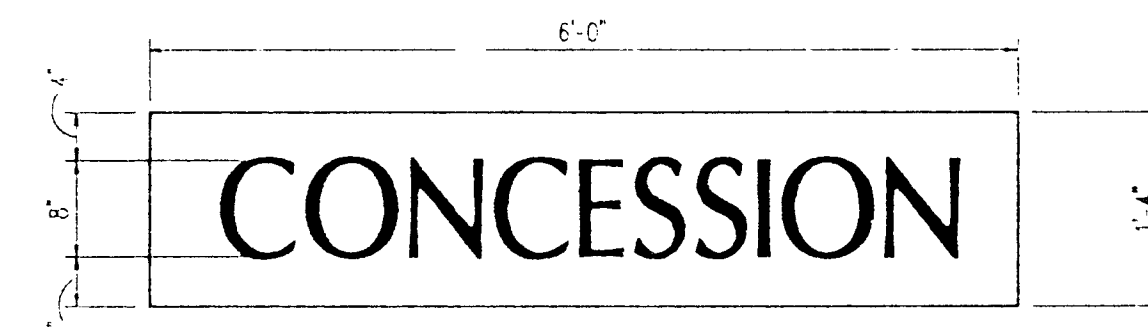

CONCESSION

NOTE: ALL STONE SIGNAGE IS TO BE ARCHITECTURAL PRECAST, TYPICAL LIMESTONE, ALTERNATE FOR LETTER INCISING AND STAIN CONTACT CERAMICA, INC. (317) 845-0087

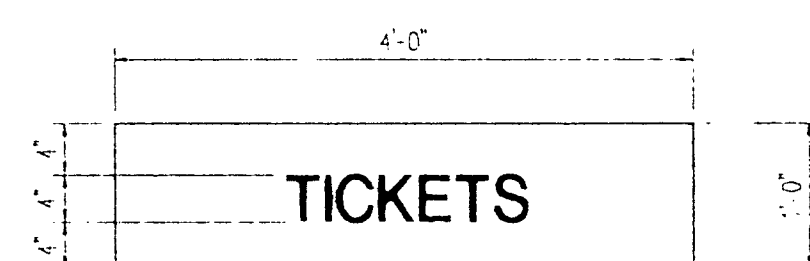


TICKETS

STONE SIGNAGE

SCALE: 3/4" = 1'-0"

12
A603

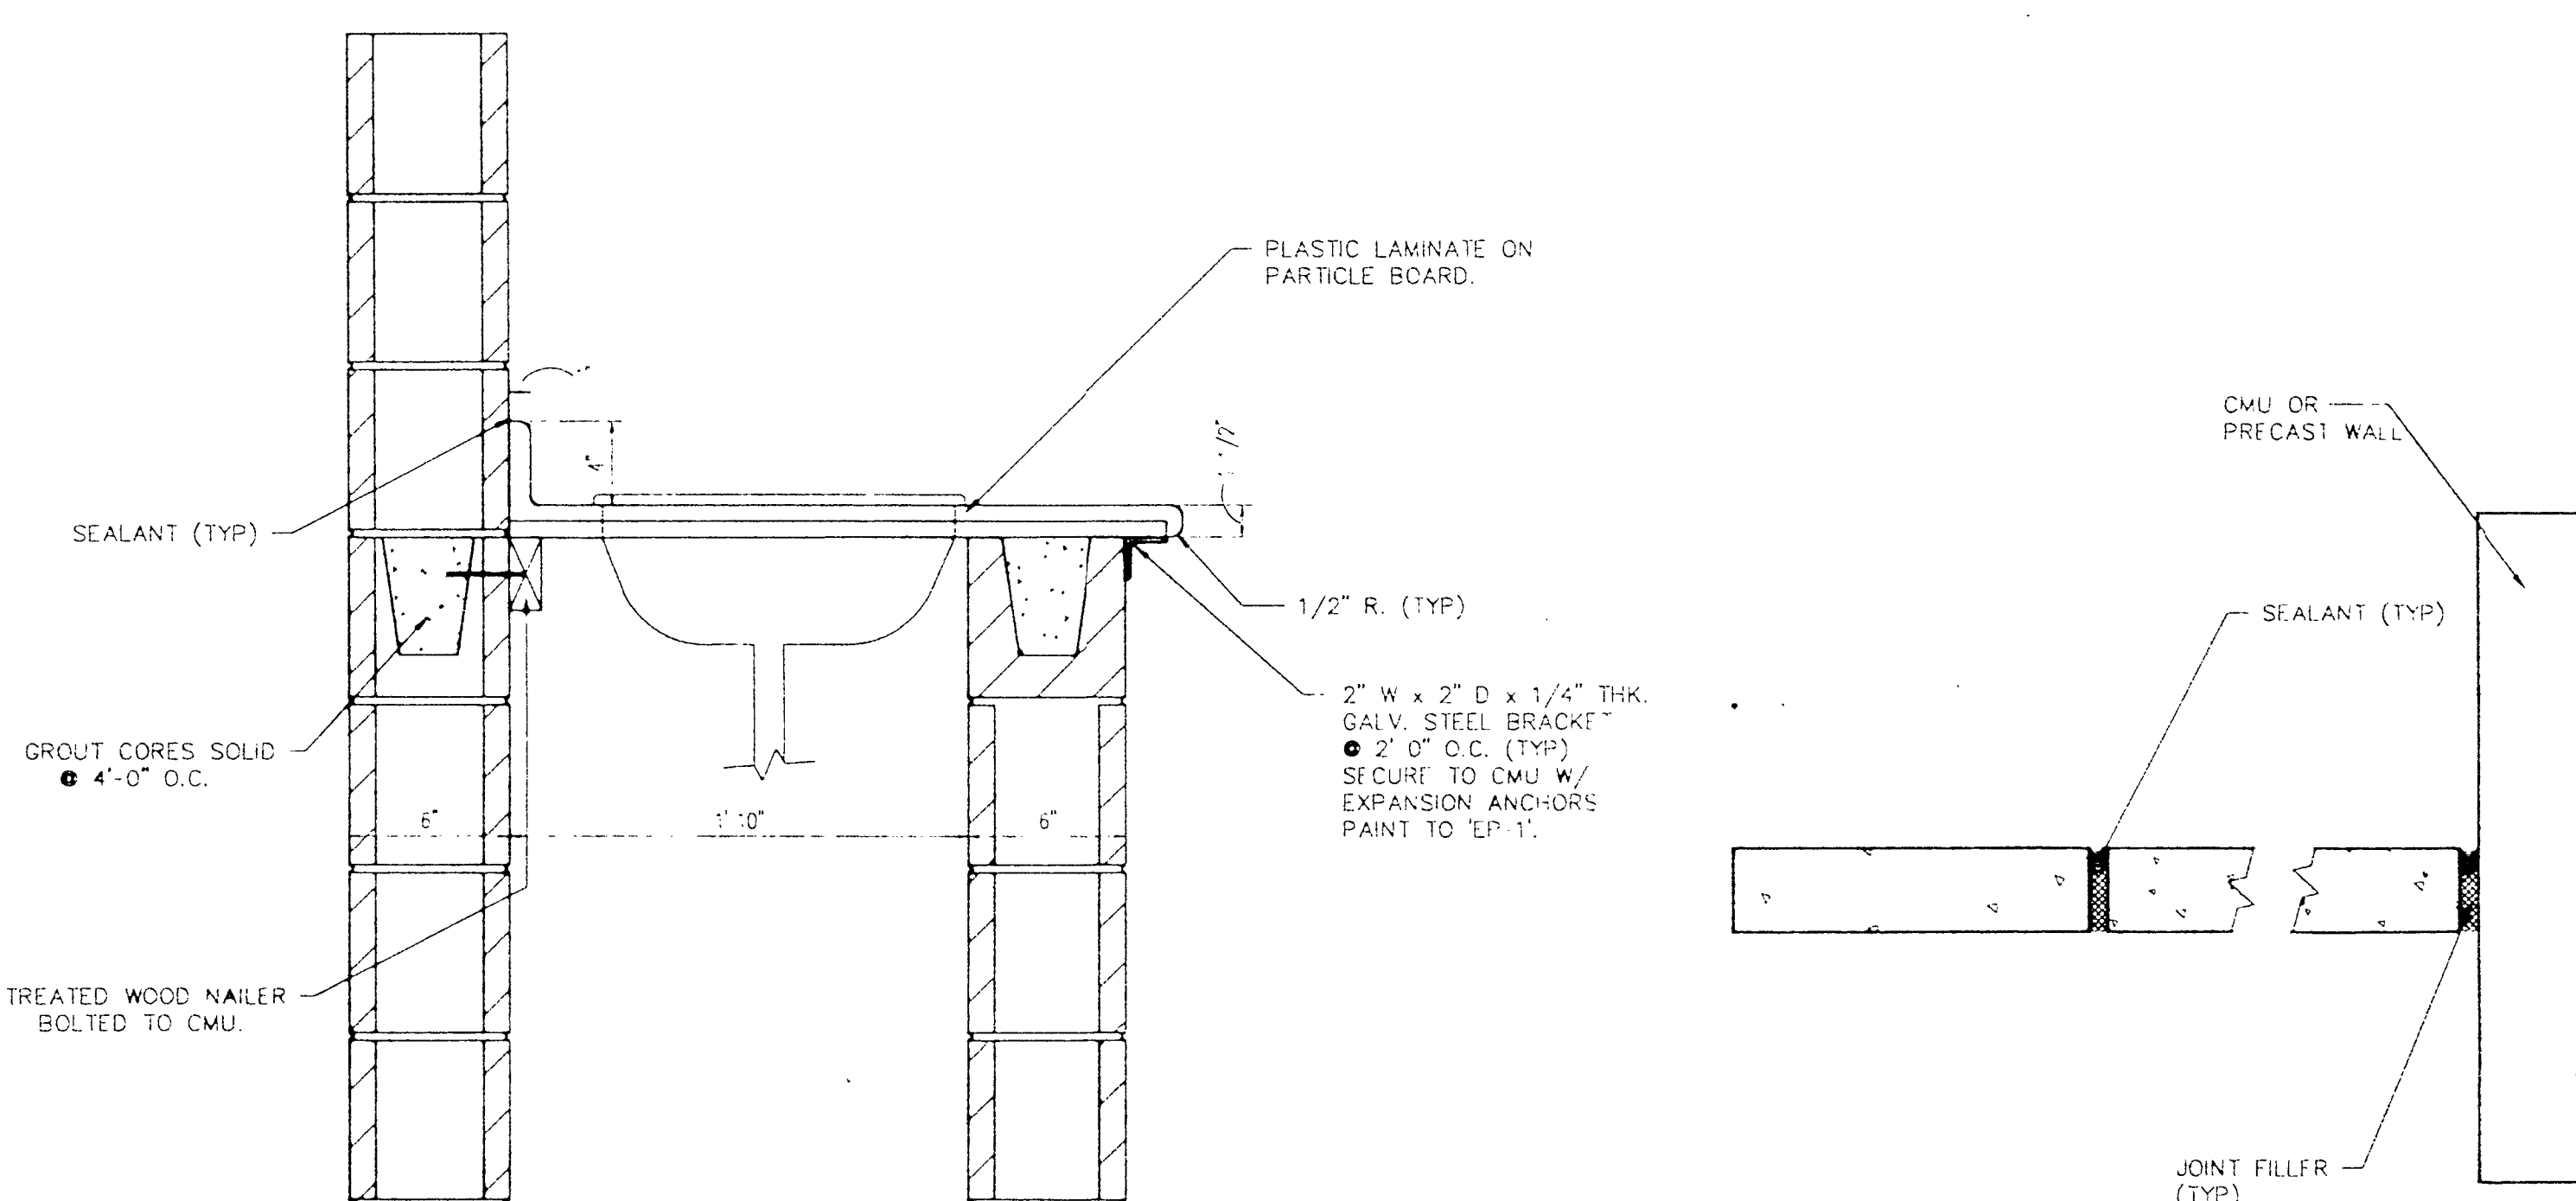

TYPICAL CONCESSION COUNTER DETAIL


SCALE: 1 1/2" = 1'-0"

11
A603

TYPICAL ISOLATION JOINTS @ VERTICAL SURFACES

SCALE: 1" = 1'-0"


10
A603

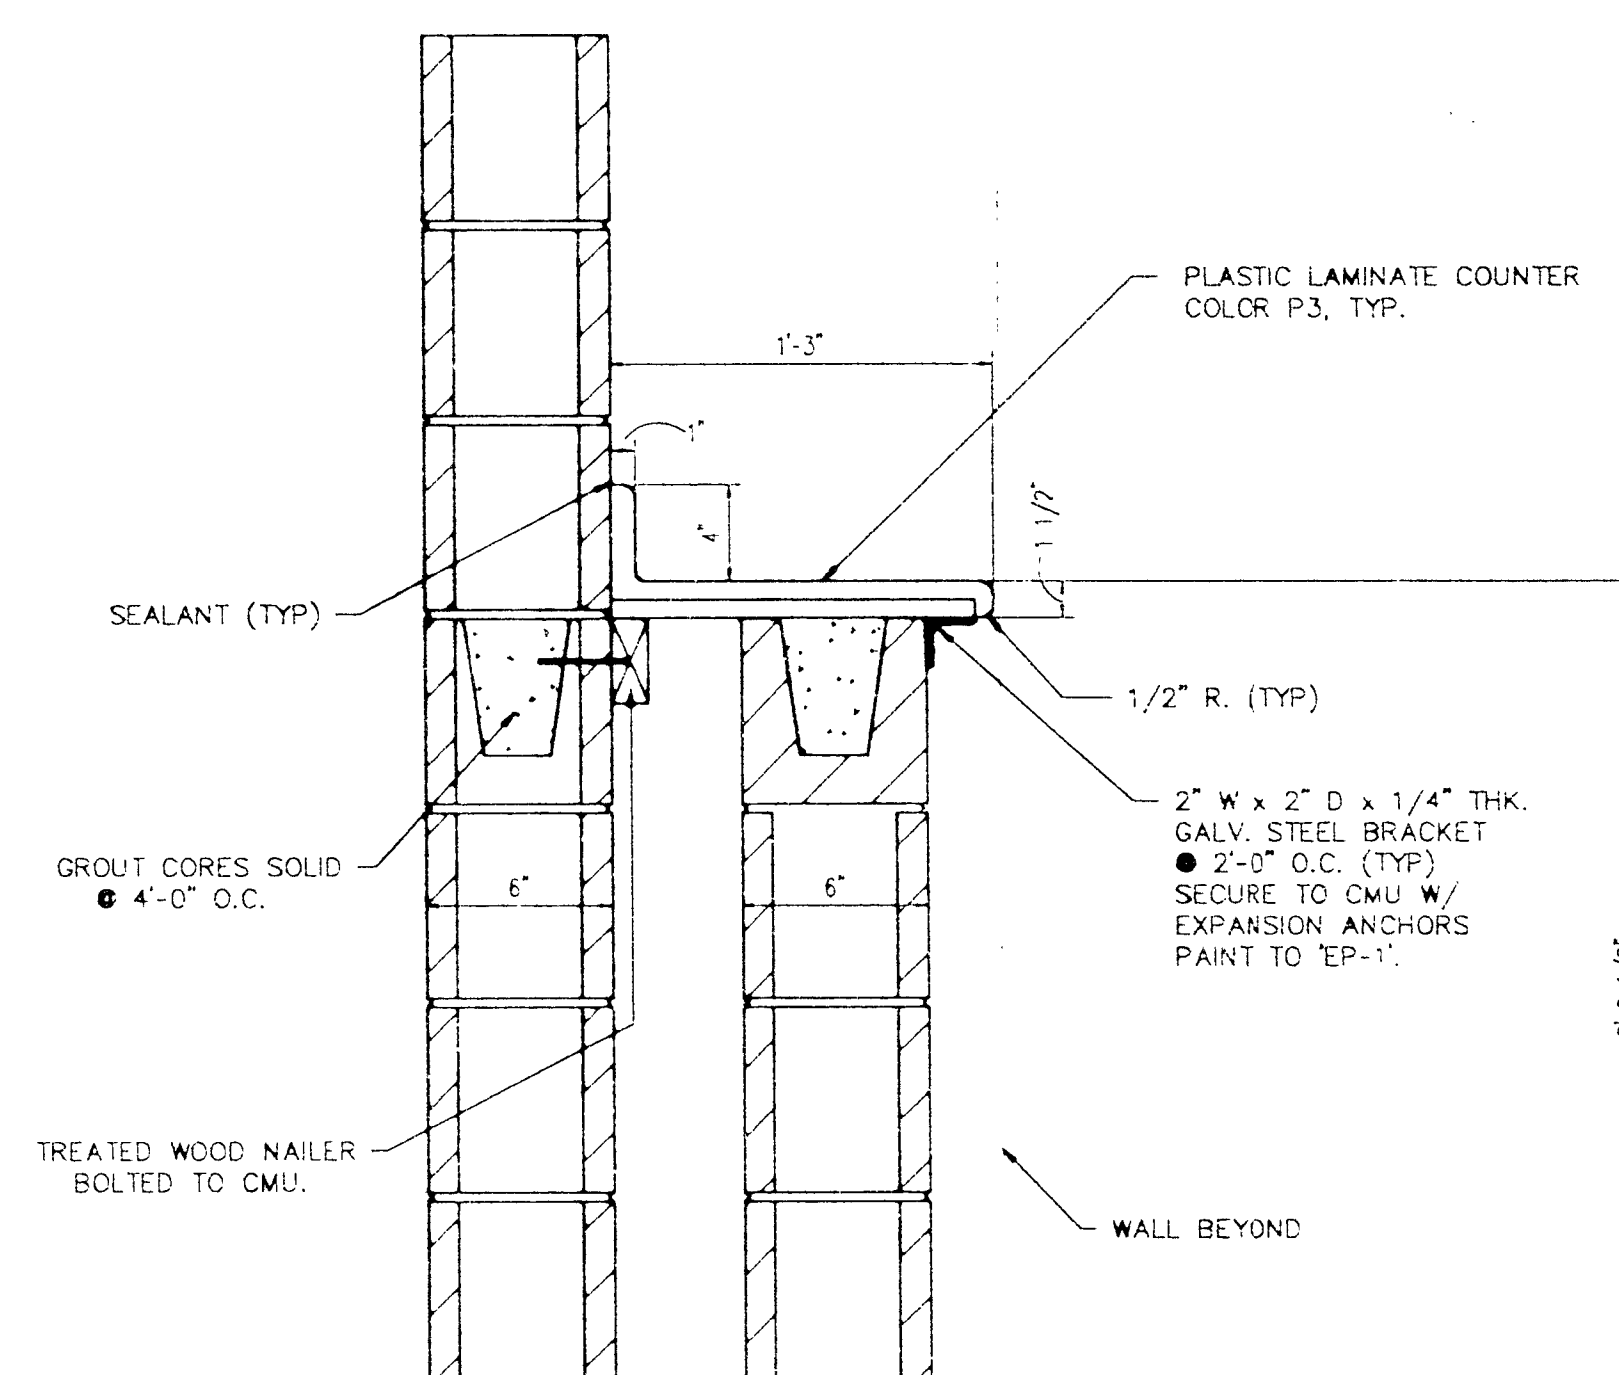

LOCKER ROOM COUNTER DETAIL


SCALE: 1 1/2" = 1'-0"

9
A603

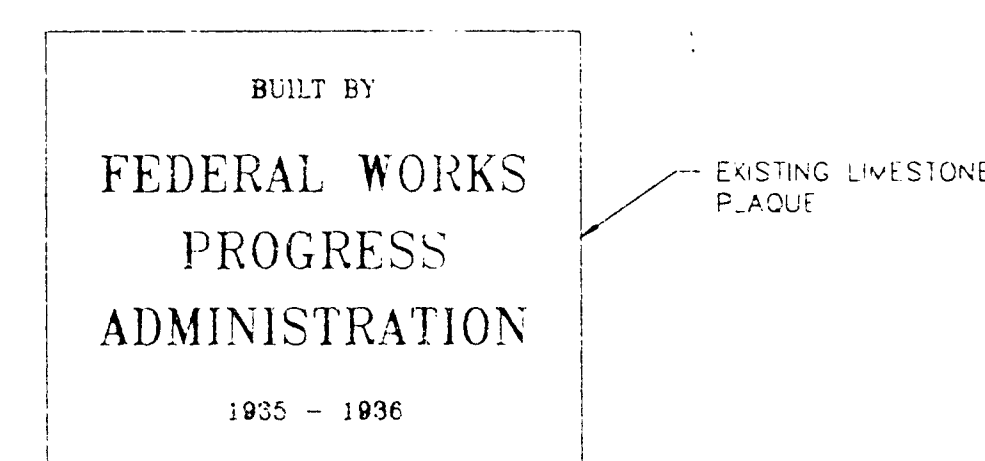

BUILT BY
FEDERAL WORKS
PROGRESS
ADMINISTRATION
1935 - 1936

EXISTING LIMESTONE
PLAQUE

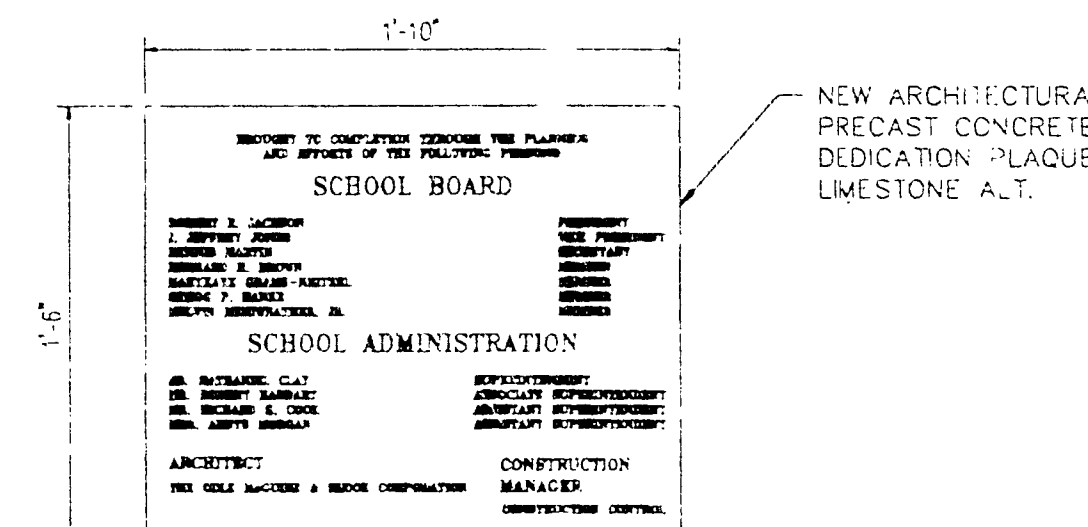


NEW ARCHITECTURAL
PRECAST CONCRETE
DEDICATION PLAQUE,
LIMESTONE ALT.

DEDICATION PLAQUES

SCALE: 1 1/2" = 1'-0"


8
A603

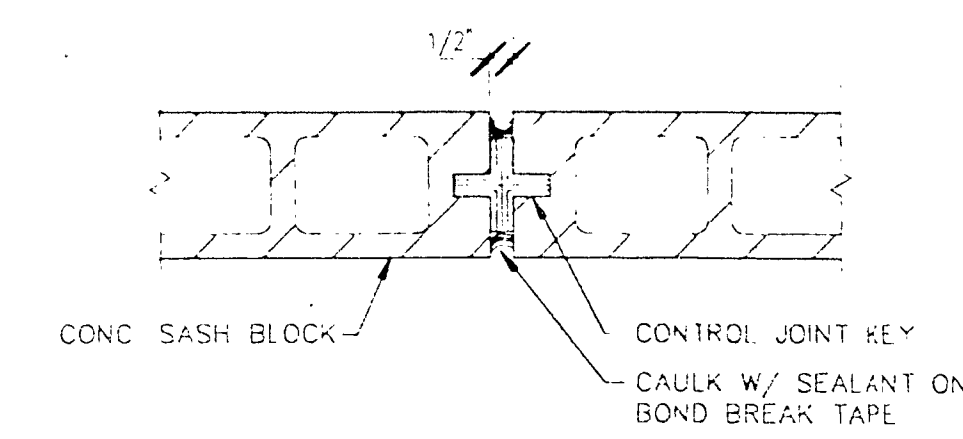

INTERIOR WALL CONTROL JOINT

SCALE: 1 1/2" = 1'-0"


7
A603

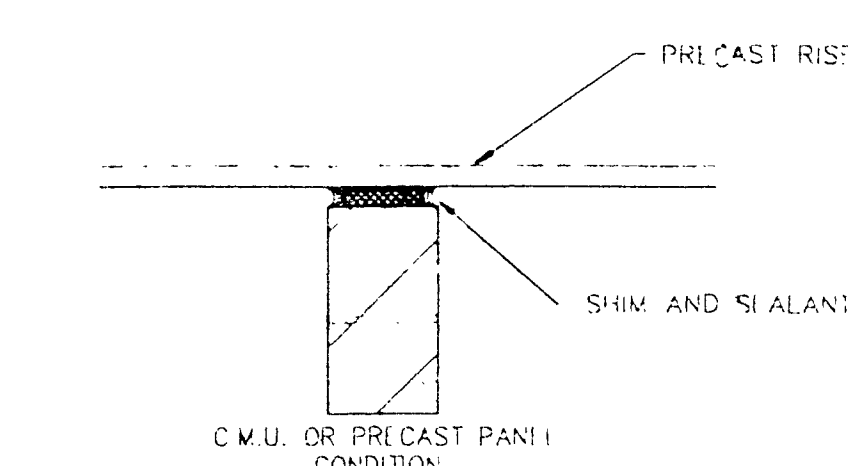

WALL TO DECK TERMINATIONS (TYP.)

SCALE: NONE


6
A603

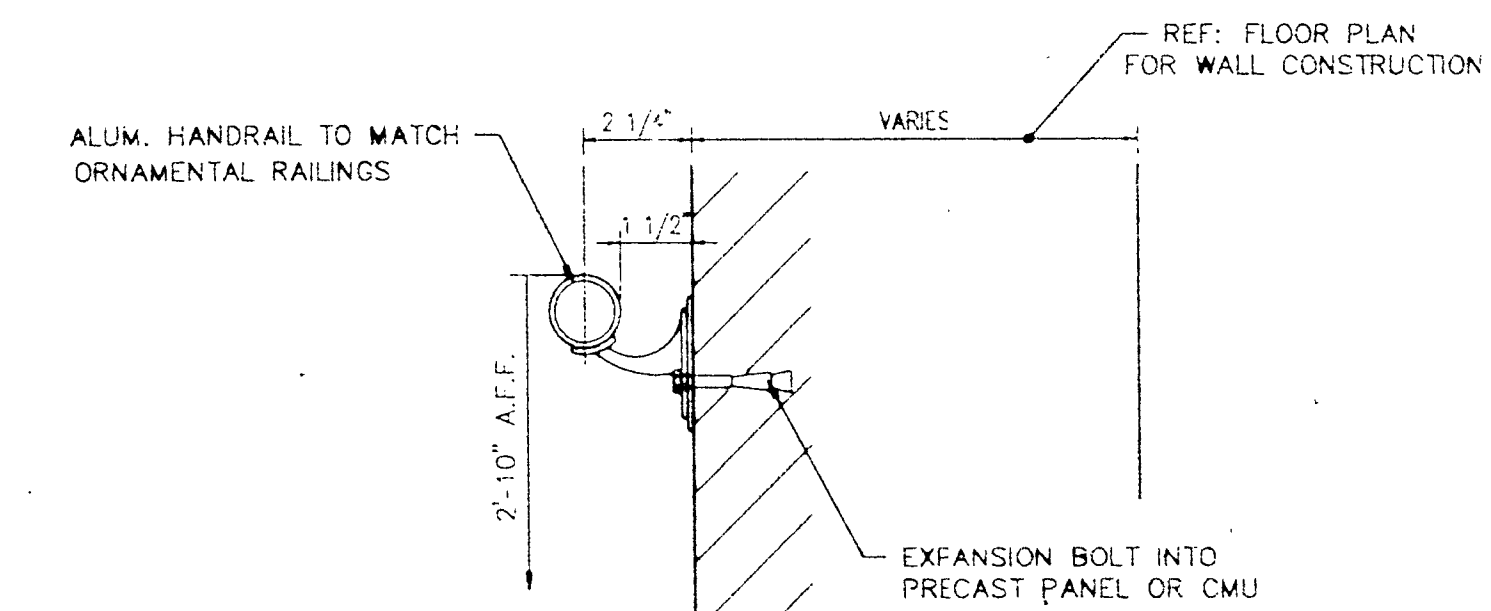

TYPICAL HANDRAIL DETAIL

SCALE: 3" = 1'-0"


5
A603

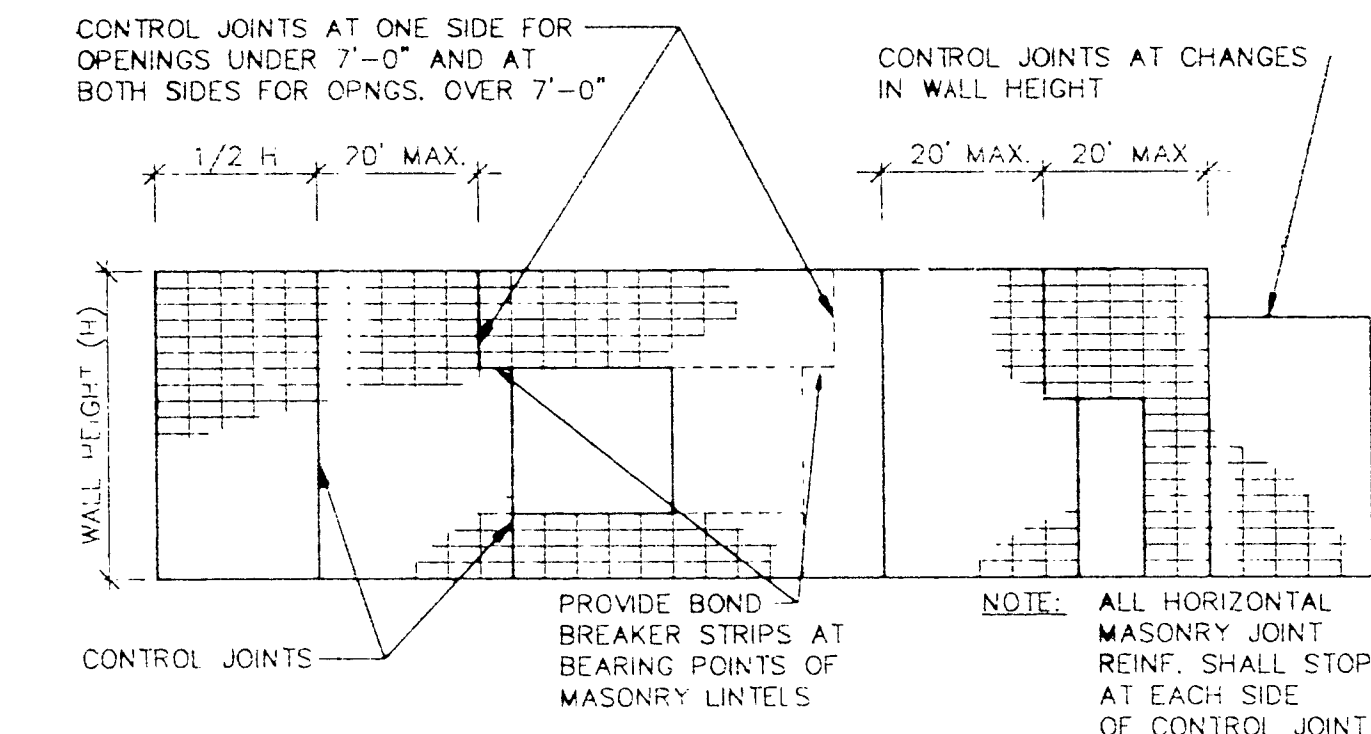

ELEVATION OF TYPICAL CONTROL JOINT LOCATIONS

SCALE: NONE


4
A603

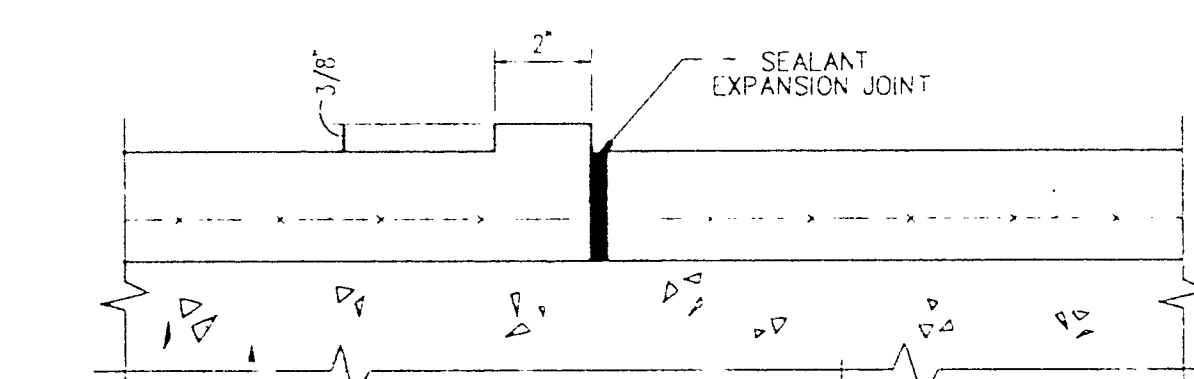

CURB @ HANDICAP SHOWER

SCALE: 3" = 1'-0"


3
A603

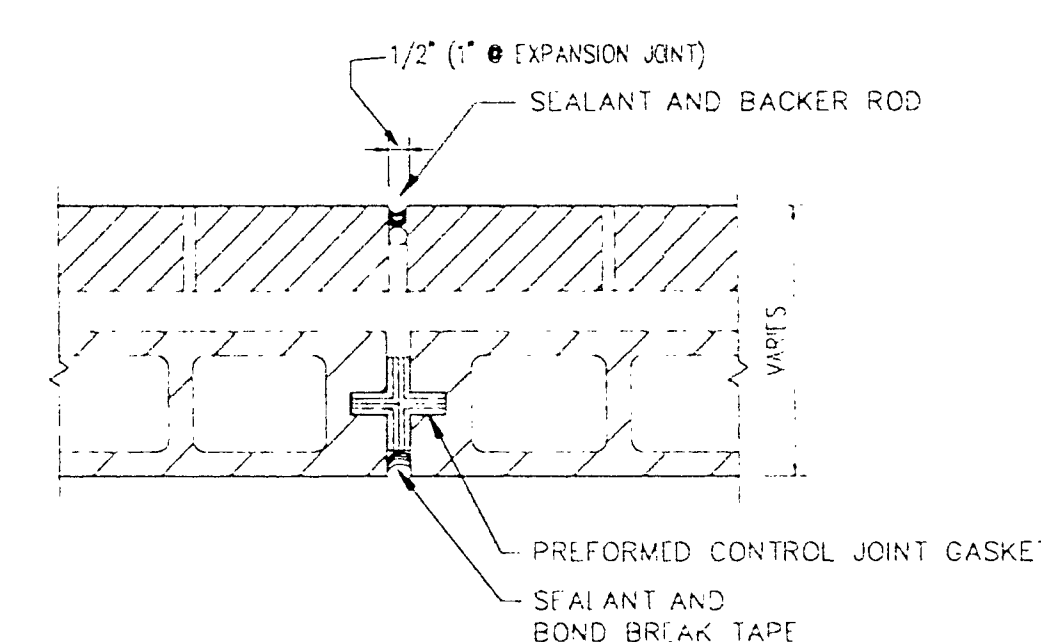

EXTERIOR WALL CONTROL JOINT

SCALE: 1 1/2" = 1'-0"

2
A603

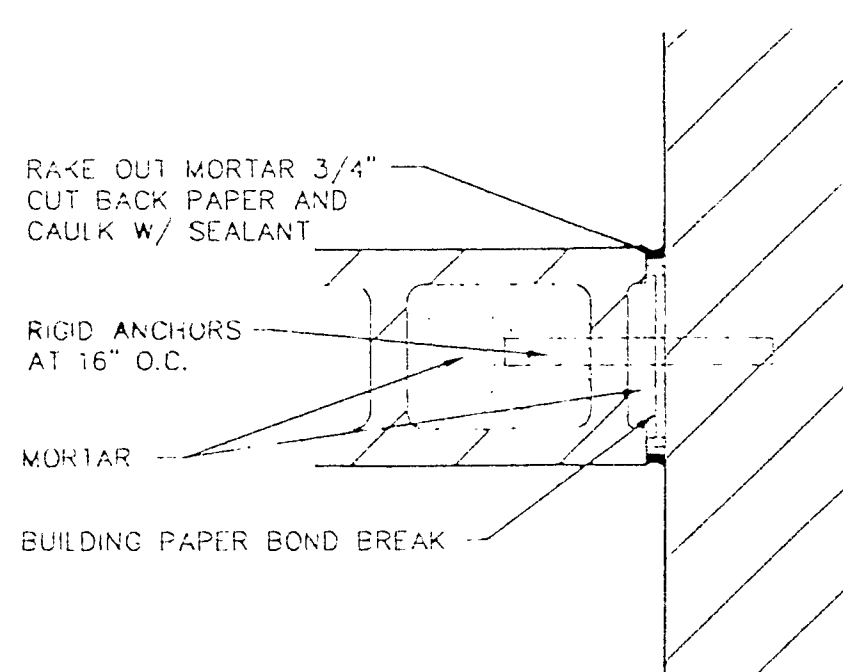

INTERSECTION OF PERPENDICULAR WALLS

SCALE: 1 1/2" = 1'-0"

1
A603



THE OGLE MCGURE & SHOOK CORPORATION
ARCHITECTURE • ENGINEERING • LANDSCAPE ARCHITECTURE • INTERIOR DESIGN
8765 NORTH STATE ROAD 37 POST OFFICE BOX 248 BLANCKEN, INDIANA 47403 812/874-2000
8275 ALLISON FORTNE TRAIL POST OFFICE BOX 5074 INDIANAPOLIS, INDIANA 46250 317/842-0000


REVISIONS

© Copyright 1994 by THE OGLE MCGURE & SHOOK CORPORATION. Copyright includes architectural work, building design, plans, drawings, and specifications. Architectural work is the property of the firm and shall remain confidential. Reproduction without written permission is prohibited.

MICHIGAN CITY SPORTS COMPLEX
AMES FIELD
MICHIGAN CITY, INDIANA

PROJECT NO. 93052
DATE: MAY 31, 1994
drawn by: MCW
checked by: GJ

A603
MSC DETAILS

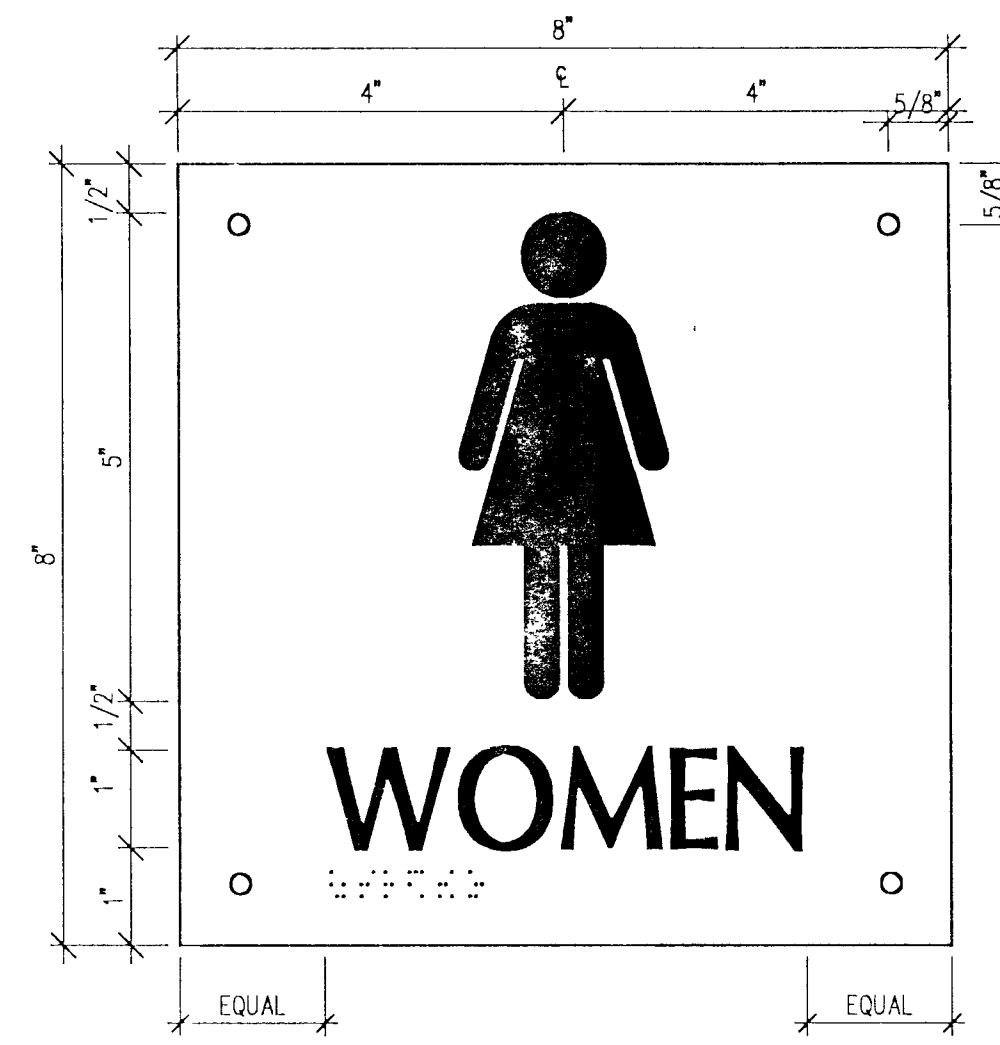


TYPE E - Symbol Sign

SCALE: 1/2"=1"




TYPE C - Warning Sign

SCALE: 1/2"=1"

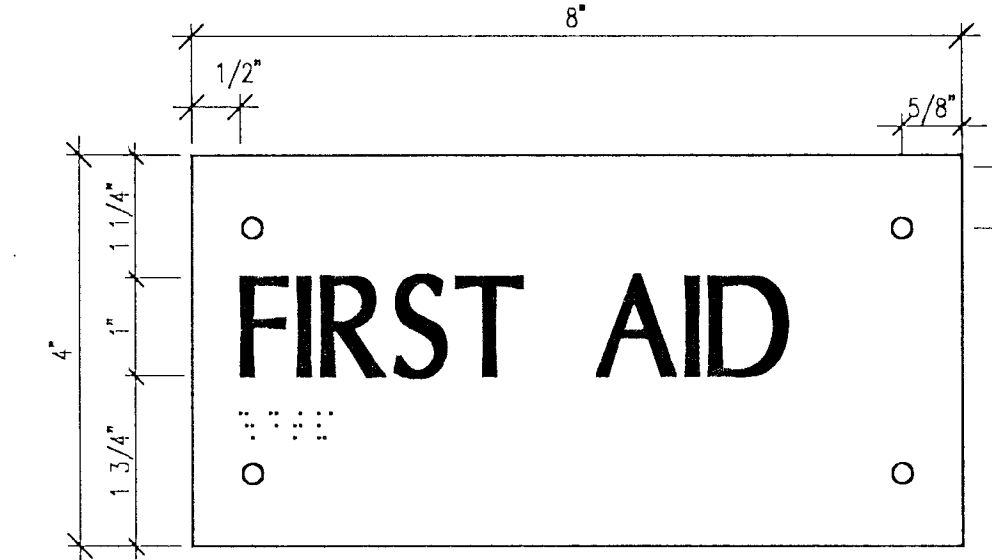


TYPE B - Room Identification Sign

SCALE: 1/2"=1"

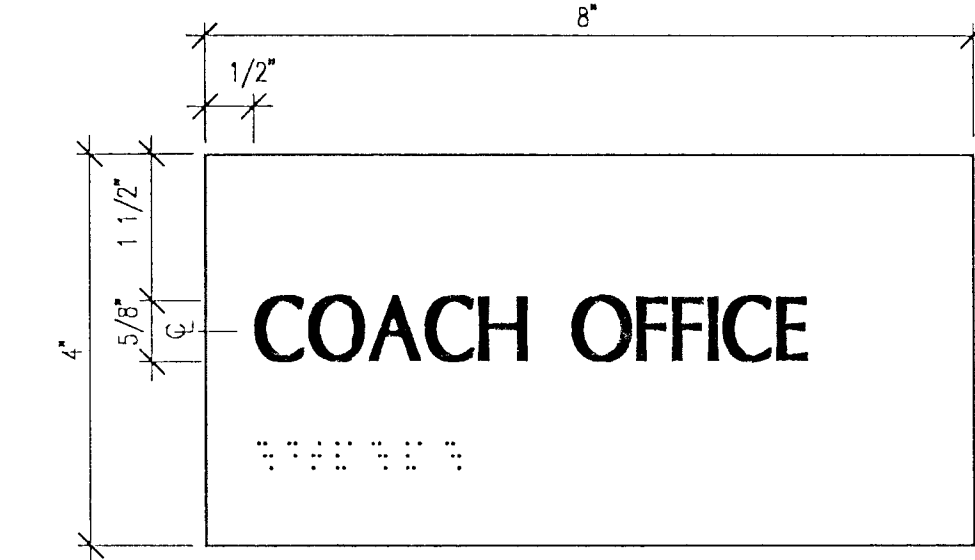

TYPE A - Room Identification Sign

SCALE: 1/2"=1"

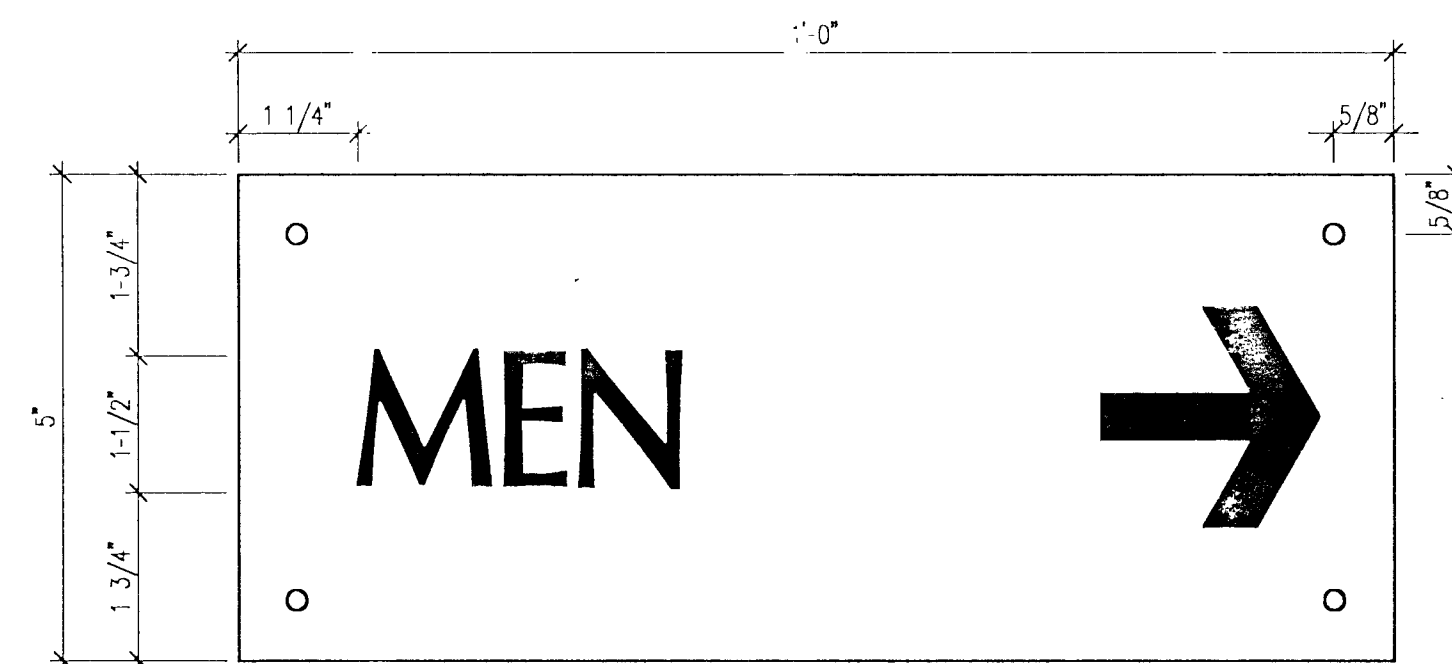


TYPE D - Directional Sign

SCALE: 1/2"=1"



TYPE F - Bulkhead Sign

SCALE: 1/2"=1"

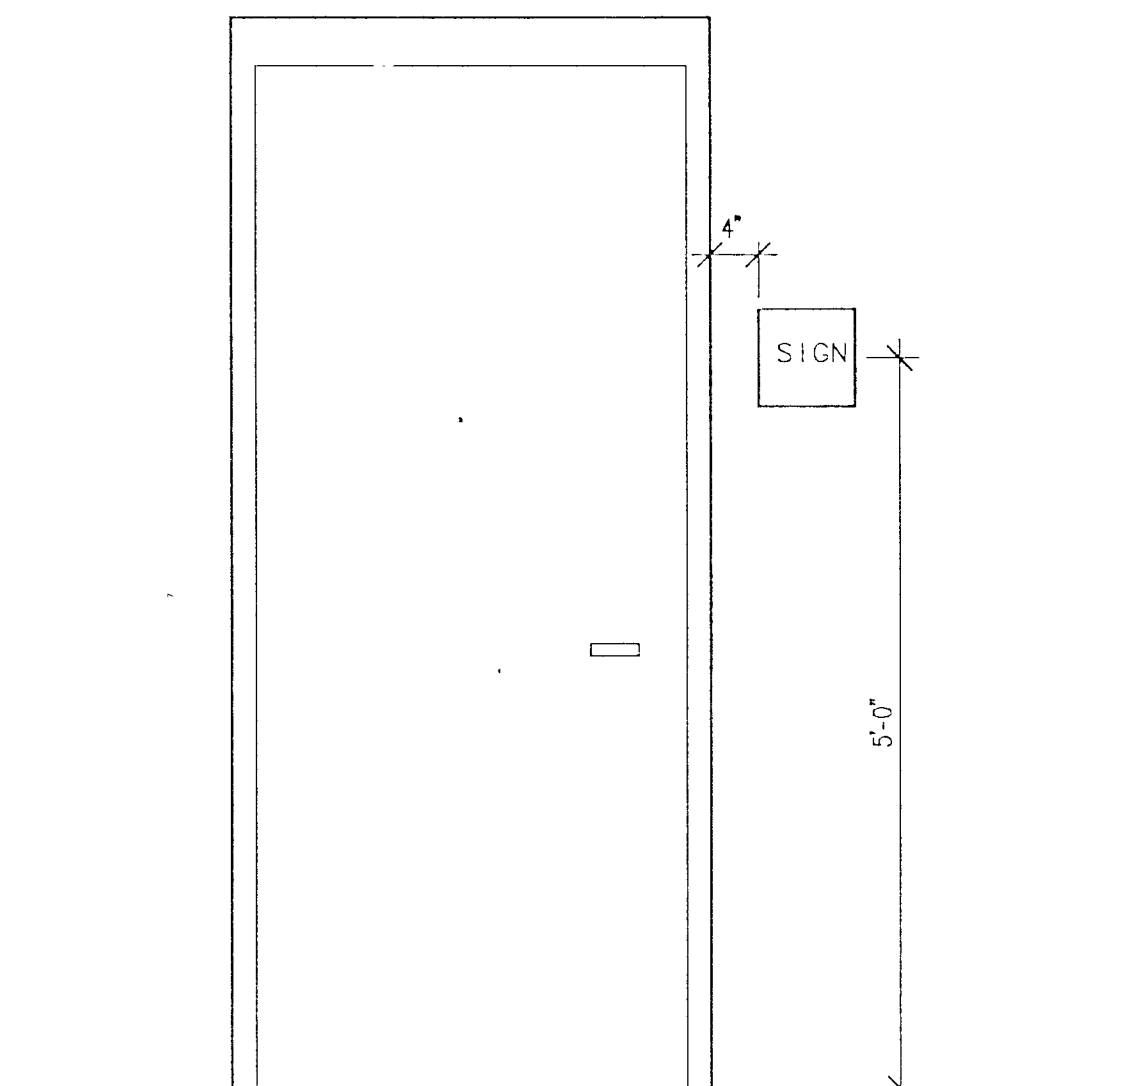


Sign Placement Elevation

SCALE: 3/4"=1'-0"



TYPE G2- Directional Sign

SCALE: 1/2"=1"

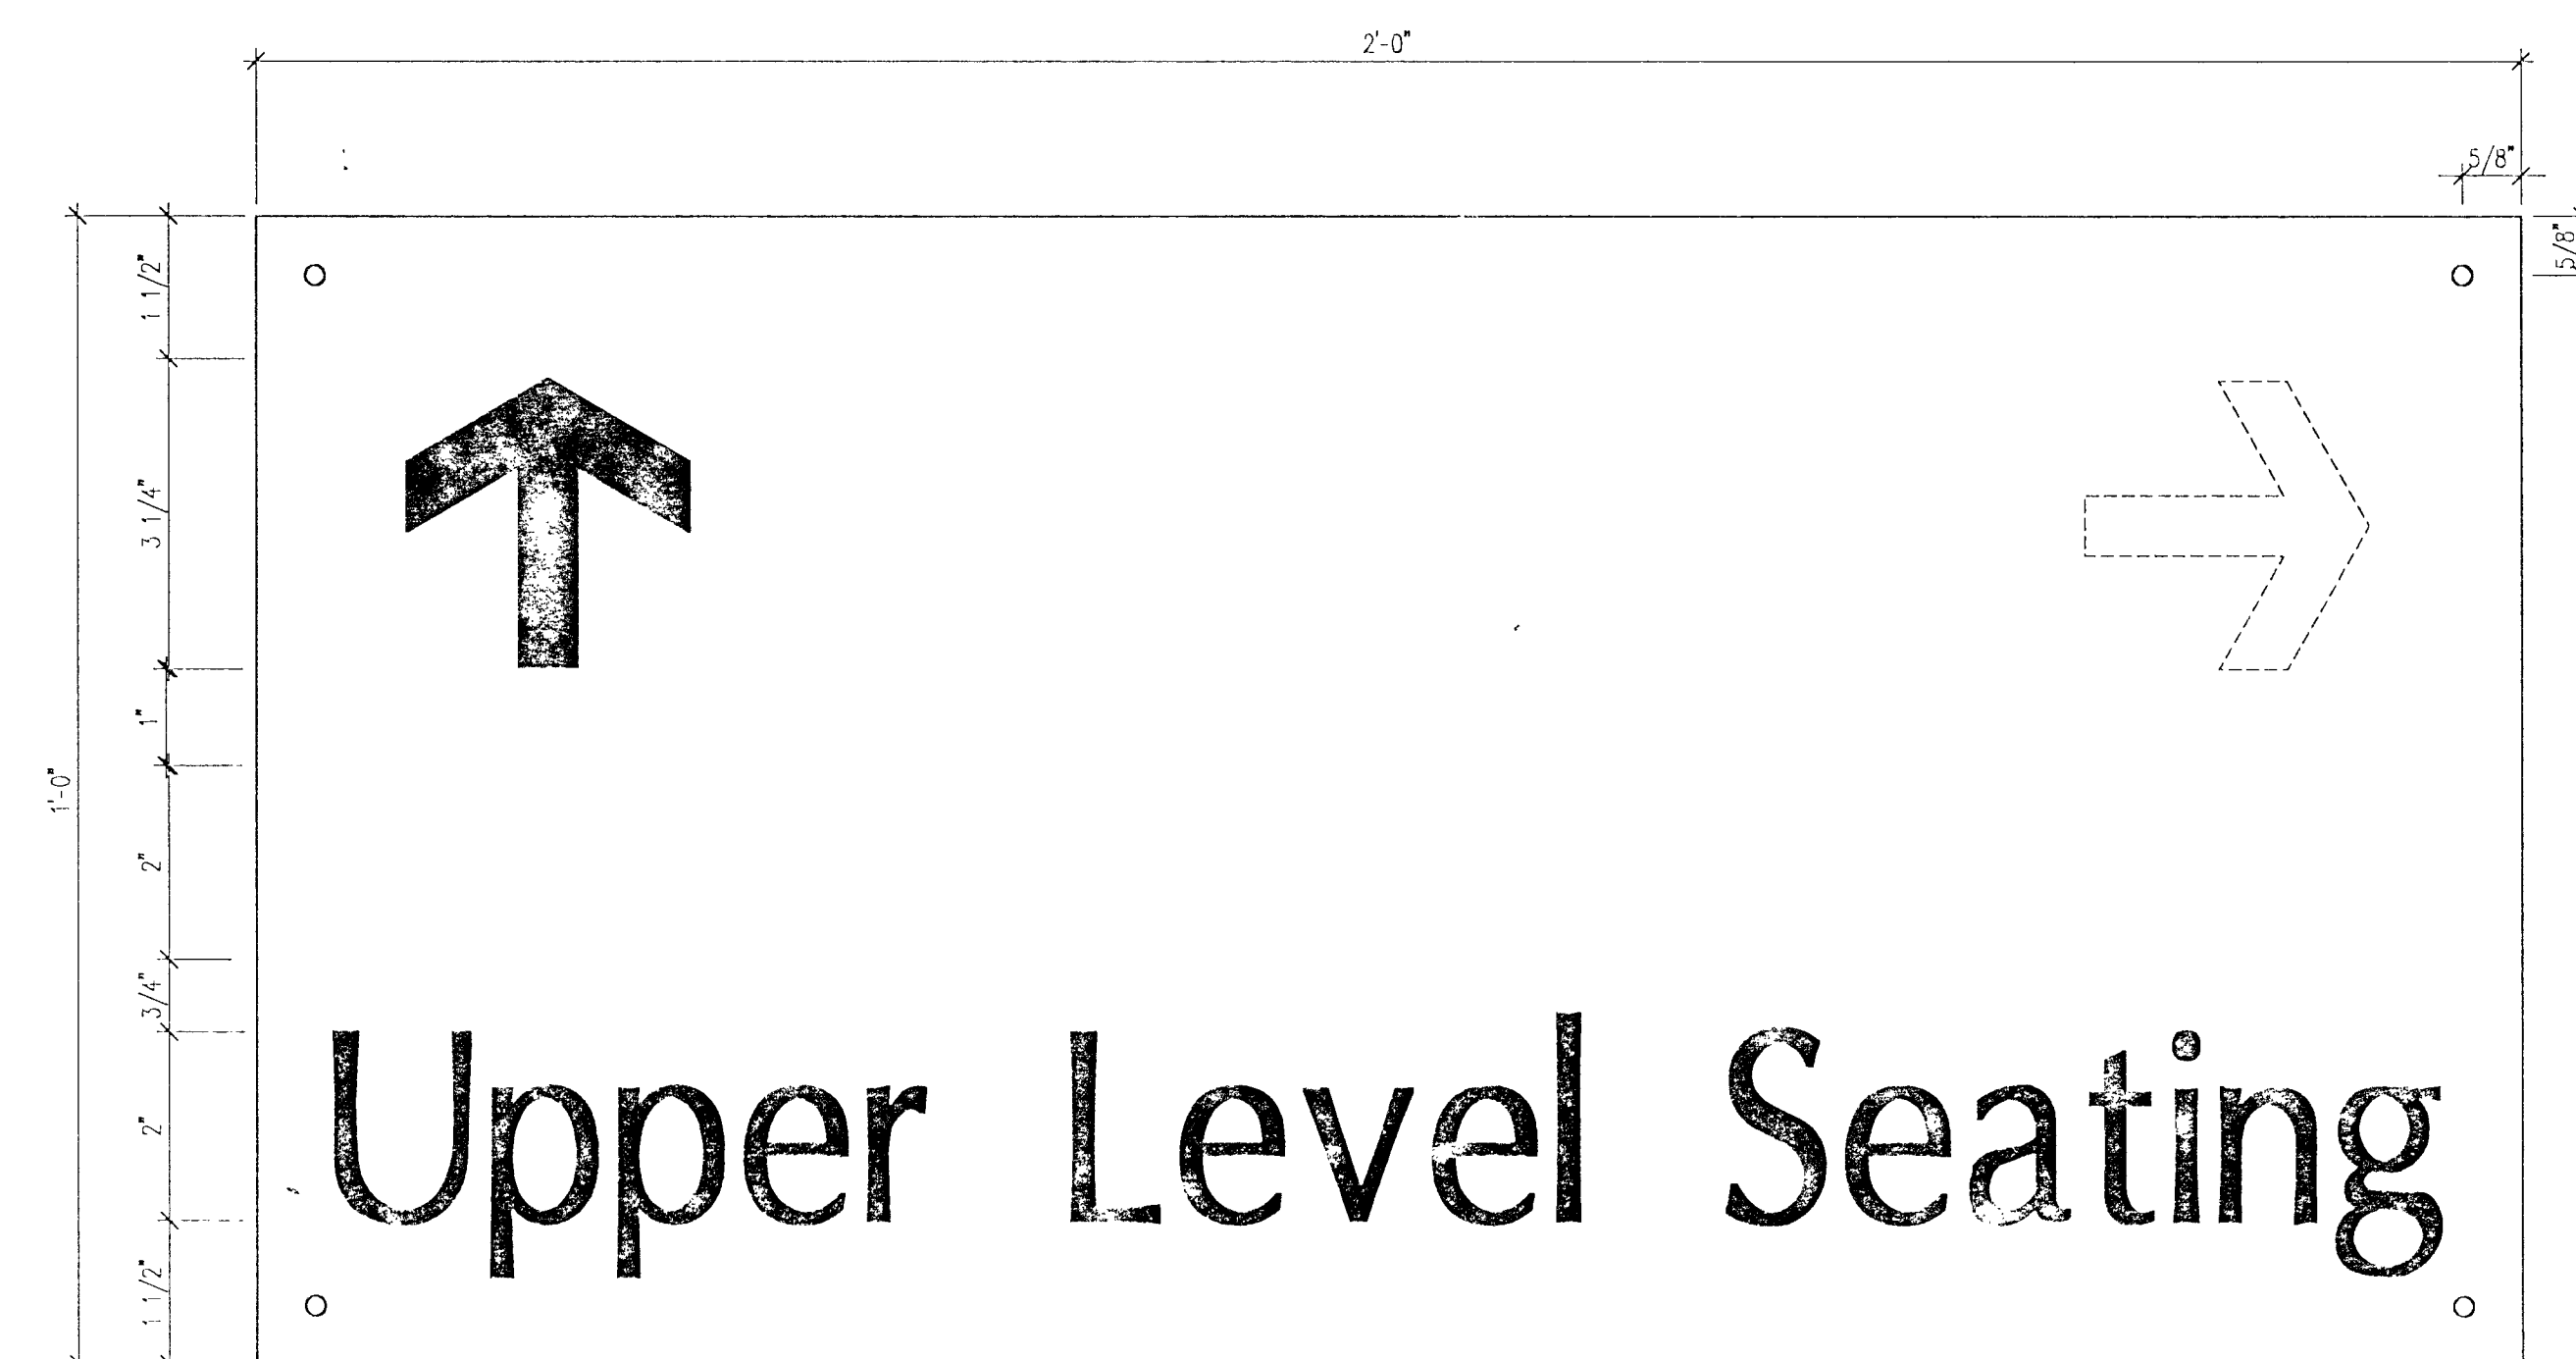

TYPE G - Directional Sign

SCALE: 1/2"=1"

CERTIFIED

THE ODLE MCGUIRE & SHOOK CORPORATION
ARCHITECTURE • ENGINEERING • LANDSCAPE ARCHITECTURE • INTERIOR DESIGN
6765 NORTH STATE ROAD 37, POST OFFICE BOX 2149, BLOOMINGTON, INDIANA 47402, 812/876-2020
6275 ALISON POINTE TRAIL, POST OFFICE BOX 50428, INDIANAPOLIS, INDIANA 46250, 317/842-1000

REVISIONS


© Copyright 1994 by THE ODLE MCGUIRE & SHOOK CORPORATION. Copyright includes architectural work, building design, plans or drawings, and specifications. Architectural work is the overall form as well as the arrangement and composition of space and materials in the design. Reproduction without written permission is prohibited.

MICHIGAN CITY SPORTS COMPLEX
AMES FIELD
MICHIGAN CITY, INDIANA

PROJECT NO. 93052
DATE MAY 31, 1994
drawn by: LEC
checked by: GJ


A604

SIGNAGE

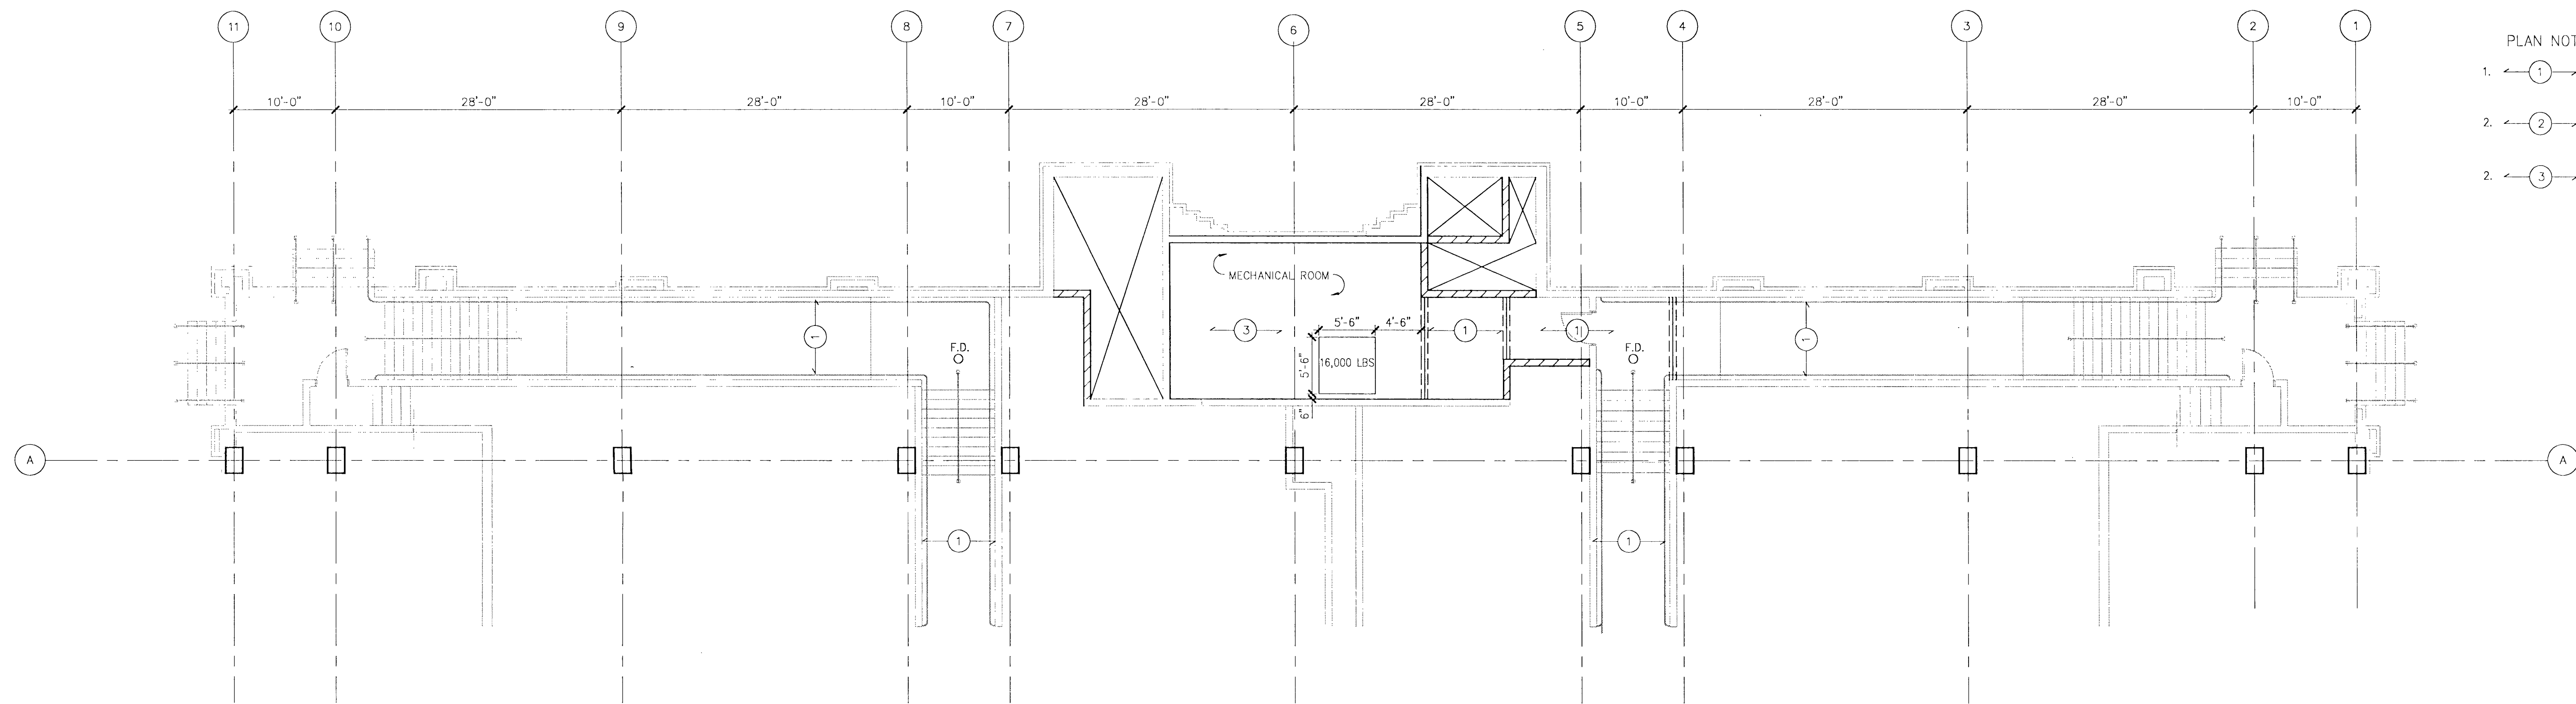

STADIUM INTERIOR RAMP & MECHANICAL ROOM FRAMING PLAN
SCALE: 1/8" = 1'-0"

- PLAN NOTES**
1. DENOTES 8" PRECAST CONCRETE HOLLOW CORE DECK WITH 2" TOPPING AND DIRECTION OF SPAN. DESIGN LOAD = LL 100 PSF + WALL LOAD
 2. DENOTES 8" PRECAST CONCRETE HOLLOW CORE DECK WITH 2" TOPPING AND DIRECTION OF SPAN. DESIGN LOAD = LL 100 PSF + WALL LOAD
 3. DENOTES 12" PRECAST CONCRETE HOLLOW CORE DECK WITH 2" TOPPING AND DIRECTION OF SPAN. DESIGN LOAD = LL 150 PSF + EQUIPMENT LOAD AS SHOWN

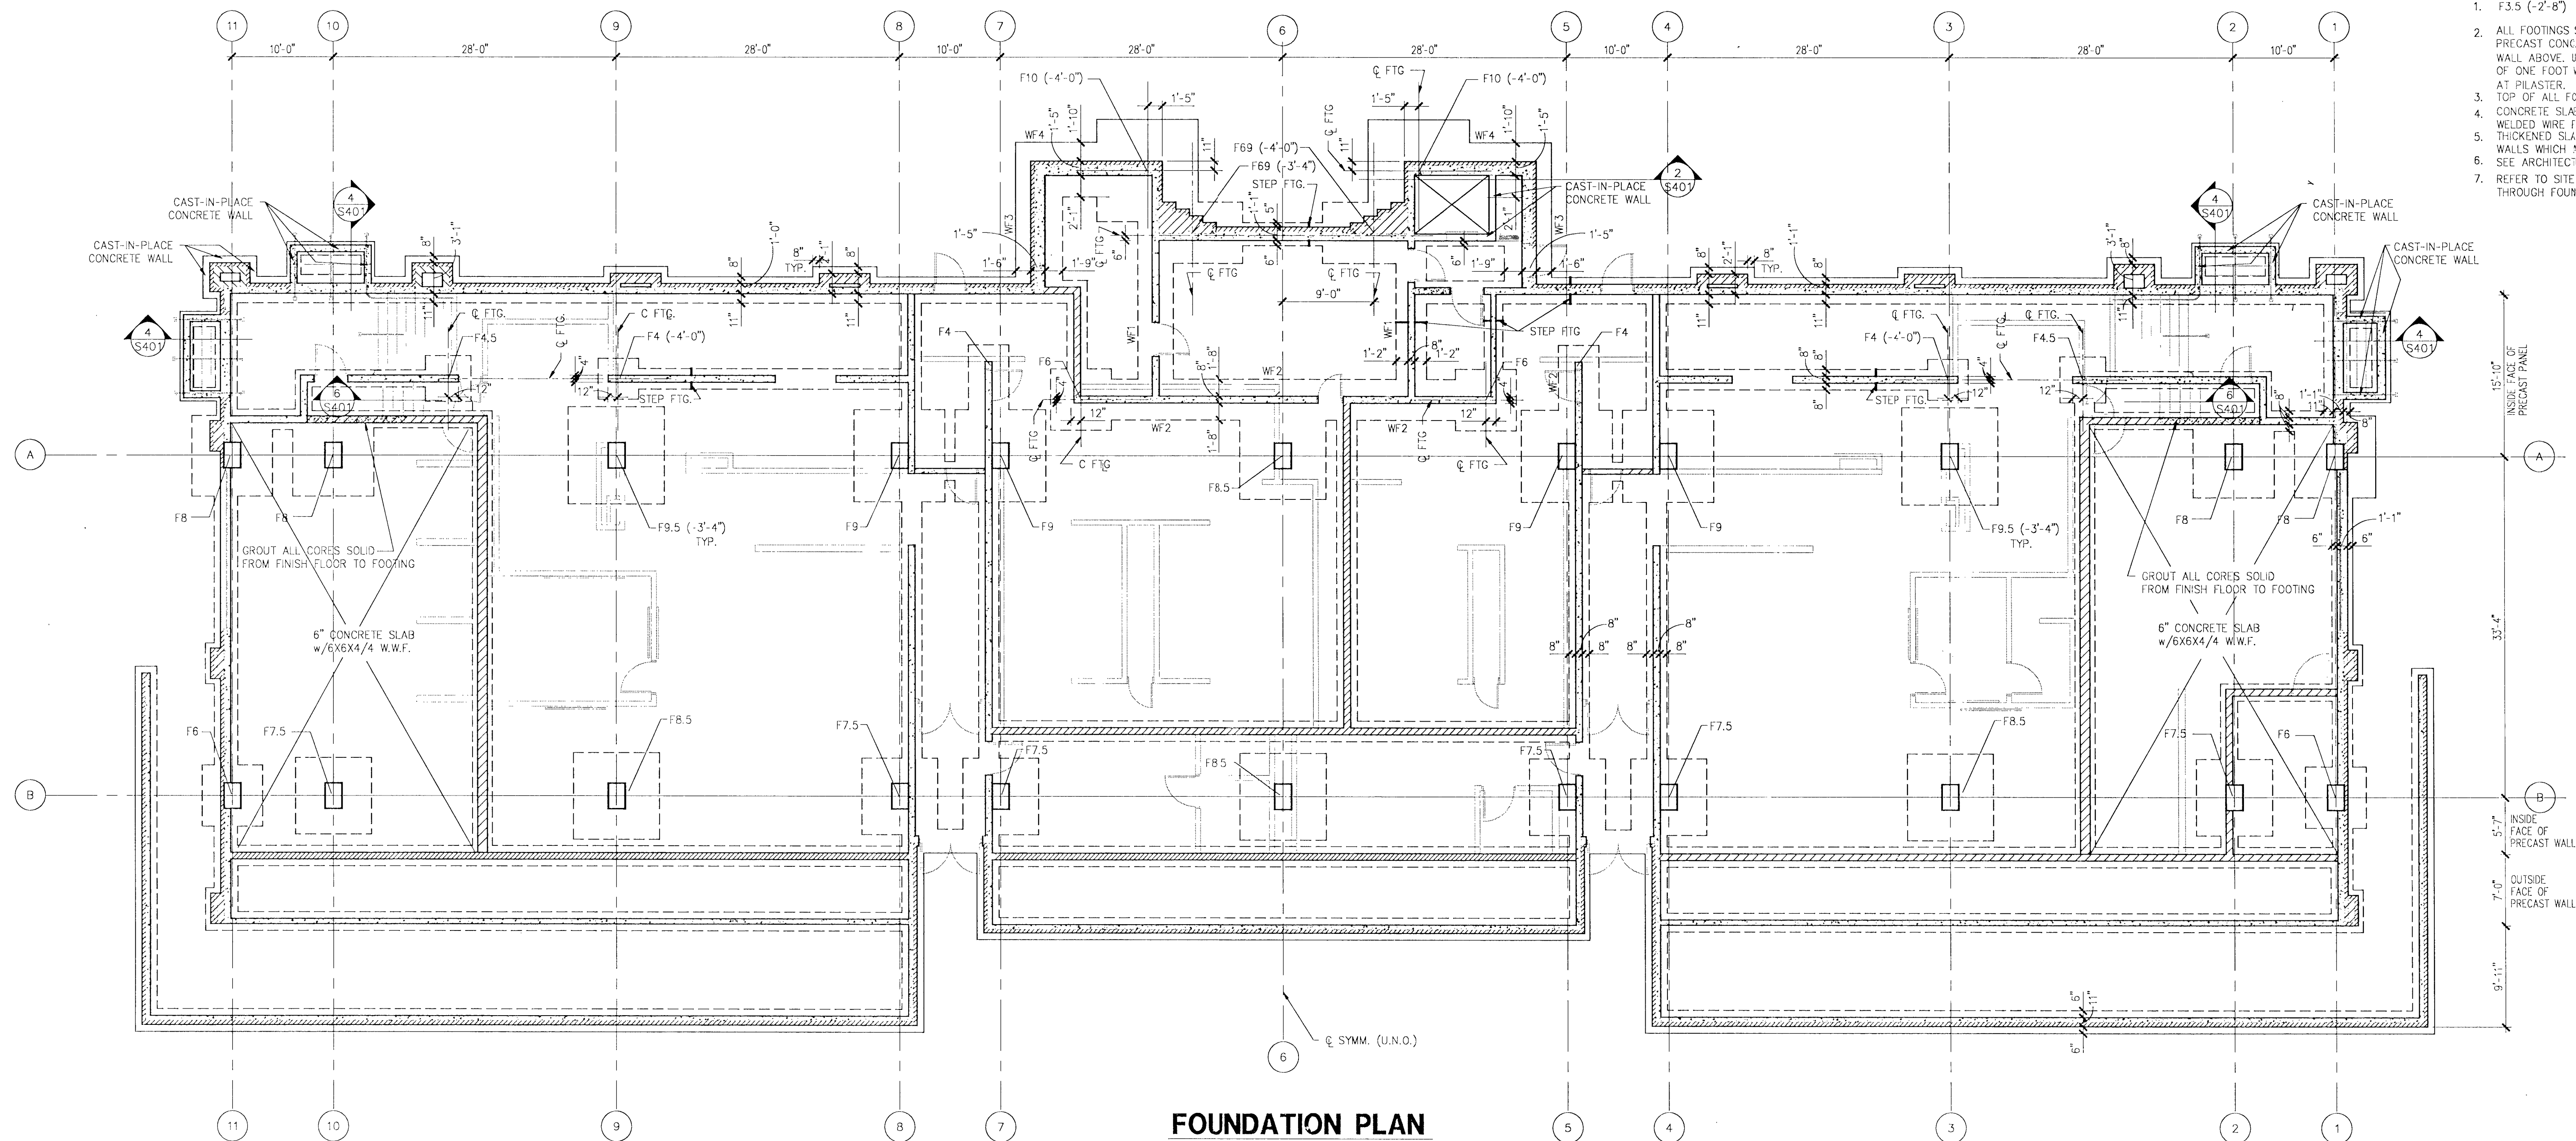

FOUNDATION PLAN
SCALE: 1/8" = 1'-0"

FOUNDATION NOTES:

1. F3.5 (-2'-8") DENOTES FOOTING SIZE AND TOP OF FOOTING ELEVATION BELOW FINISH ELEVATION OF 0'-0"
2. ALL FOOTINGS SHALL BE 1'-0" THICK FOR MASONRY WALL OR 1'-3" THICK FOR PRECAST CONC. PANEL WALL AND 1'-0" GREATER THAN THE WIDTH OF FOUNDATION WALL ABOVE. U.N.O. PROVIDE 1-#5 CONTINUOUS BAR FOR EACH FOOT OR A FRACTION OF ONE FOOT WIDTH OF FOOTING. ALSO PROVIDE #5 @ 12" O.C. E.W. TRANSVERSE BARS AT PILASTER.
3. TOP OF ALL FOOTINGS ARE TO BE 3' 4" BELOW FINISH FLOOR, U.N.O.
4. CONCRETE SLAB ON GRADE SHALL BE 4" THICK, REINFORCED WITH 6X6-8/8 WELDED WIRE FABRIC, ON VAPOR BARRIER OVER 4" DRAINAGE FILL, U.N.O.
5. THICKENED SLAB SHALL BE PROVIDED UNDER ALL INTERIOR NON-LOAD BEARING WALLS WHICH ARE 6" OR WIDER. SEE TYPICAL THICKENED SLAB DETAIL ON S501.
6. SEE ARCHITECTURAL DRAWINGS FOR ADDITIONAL DIMENSIONS AND SECTIONS.
7. REFER TO SITE DRAWINGS FOR LOCATION OF PIPES. PROVIDE SLEEVE THROUGH FOUNDATION MASONRY.

FOOTING SCHEDULE		
MARK	FOOTING SIZE L W D	REINFORCING
F4	4'-0"x4'-0"x1'-2"	5 - #5
F4.5	4'-6"x4'-6"x1'-2"	6 - #5
F6	6'-0"x6'-0"x1'-5"	7 - #7
F6.9	6'-0"x6'-0"x2'-3"	#7 @ 11" O.C.
F7.5	7'-6"x7'-6"x1'-9"	8 - #7
F8	8'-0"x8'-0"x1'-10"	9 - #7
F8.5	8'-6"x8'-6"x1'-10"	10 - #7
F9	9'-0"x9'-0"x2'-0"	10 - #8
F9.5	9'-6"x9'-6"x2'-0"	10 - #8
F10	10'-0"x10'-0"x2'-3"	12 - #8
WF1	15"	3-#5 LONG
WF2	15"	4-#5 LONG
WF3	17"	#5 @ 12" O.C. TRANS
WF4	17"	5-#5 LONG
		#5 @ 12" O.C. TRANS
		6-#5 LONG
		#6 @ 12" O.C. TRANS



CERTIFIED

THE ODLE MCGUIRE & SHOOK CORPORATION
ARCHITECTURE • ENGINEERING • LANDSCAPE ARCHITECTURE • INTERIOR DESIGN
6765 NORTH STATE ROAD 37, POST OFFICE BOX 2149, BLOOMINGTON, INDIANA 47402, 812/876-2000
8275 ALLISON POINTE TRAIL, POST OFFICE BOX 30426, INDIANAPOLIS, INDIANA 46230, 317/642-0000

REVISIONS


© Copyright 1994 by THE ODLE MCGUIRE & SHOOK CORPORATION. Copyright includes architectural work, building design, plans, drawings, and specifications. Architectural work is the result of the design and engineering process and is the property of THE ODLE MCGUIRE & SHOOK CORPORATION. Reproduction without written permission is prohibited.

MICHIGAN CITY SPORTS COMPLEX
AMES FIELD
MICHIGAN CITY, INDIANA

PROJECT NO. 93052
DATE: MAY 31, 1994
drawn by: JAW
checked by: JBF

S201
FOUNDATION PLAN

1/8" = 1'-0"

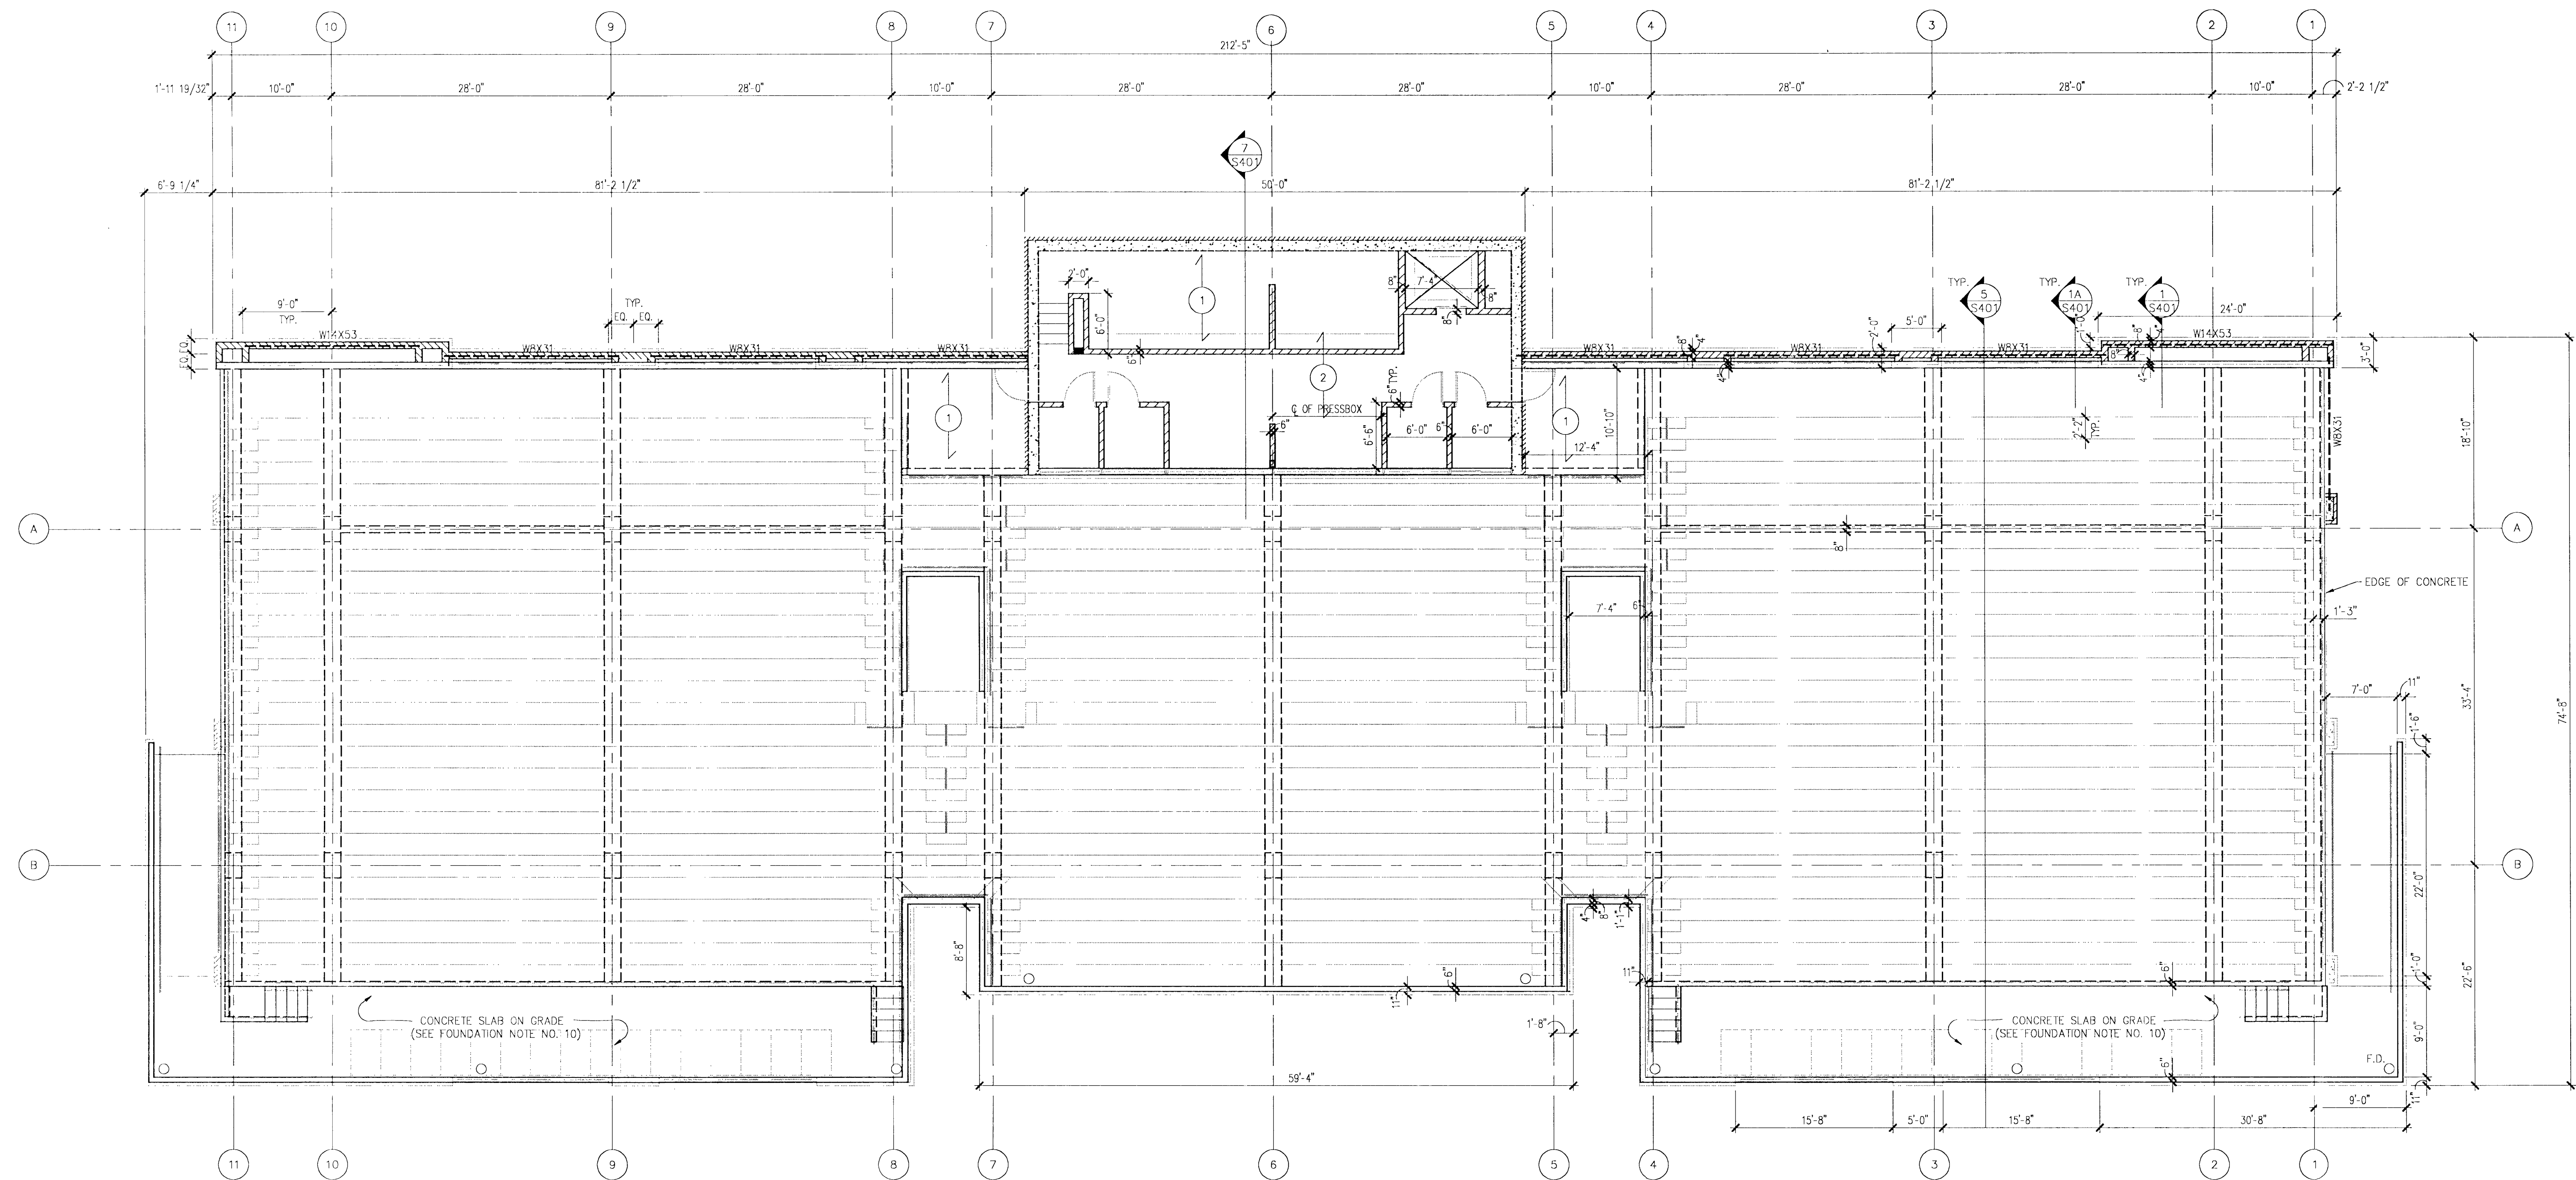


STADIUM SEATING FRAMING PLAN
SCALE: 1/8" = 1'-0"

PLAN NOTES


1. DENOTES 6" PRECAST CONCRETE HOLLOW CORE DECK WITH 2" TOPPING AND DIRECTION OF SPAN. DESIGN LOAD = L.L. 100 PSF + WALL LOAD.
2. DENOTES 8" PRECAST CONCRETE HOLLOW CORE DECK WITH 2" TOPPING AND DIRECTION OF SPAN. DESIGN LOAD = L.L. 100 PSF + WALL LOAD.

FOUNDATION NOTES

- F3.5 (-2'-8") DENOTES FOOTING SIZE AND TOP OF FOOTING ELEVATION BELOW FINISH ELEVATION OF 0'-0".
- ALL FOOTINGS SHALL BE 1'-0" THICK AND 1'-0" GREATER THAN THE WIDTH OF FOUNDATION WALL ABOVE, U.N.O. PROVIDE 1-#5 CONTINUOUS BAR FOR EACH FOOT OR A FRACTION OF ONE FOOT WIDTH OF FOOTING.
- TOP OF ALL EXTERIOR FOOTINGS ARE TO BE 3'-4" BELOW FINISH FLOOR, U.N.O.
- CONCRETE SLAB ON GRADE SHALL BE 4" THICK, REINFORCED WITH 6#6-8/8 WELDED WIRE FABRIC, ON VAPOR BARRIER OVER 4" DRAINAGE FILL, U.N.O.
- THICKENED SLAB SHALL BE PROVIDED UNDER ALL INTERIOR NON-LOAD BEARING WALLS WHICH ARE 6" OR WIDER. SEE TYPICAL THICKENED SLAB DETAIL ON S401.
- SEE ARCHITECTURAL DRAWINGS FOR ADDITIONAL DIMENSIONS AND SECTIONS.
- REFER TO SITE DRAWINGS FOR LOCATION OF PIPES. PROVIDE SLEEVE THROUGH FOUNDATION MASONRY.

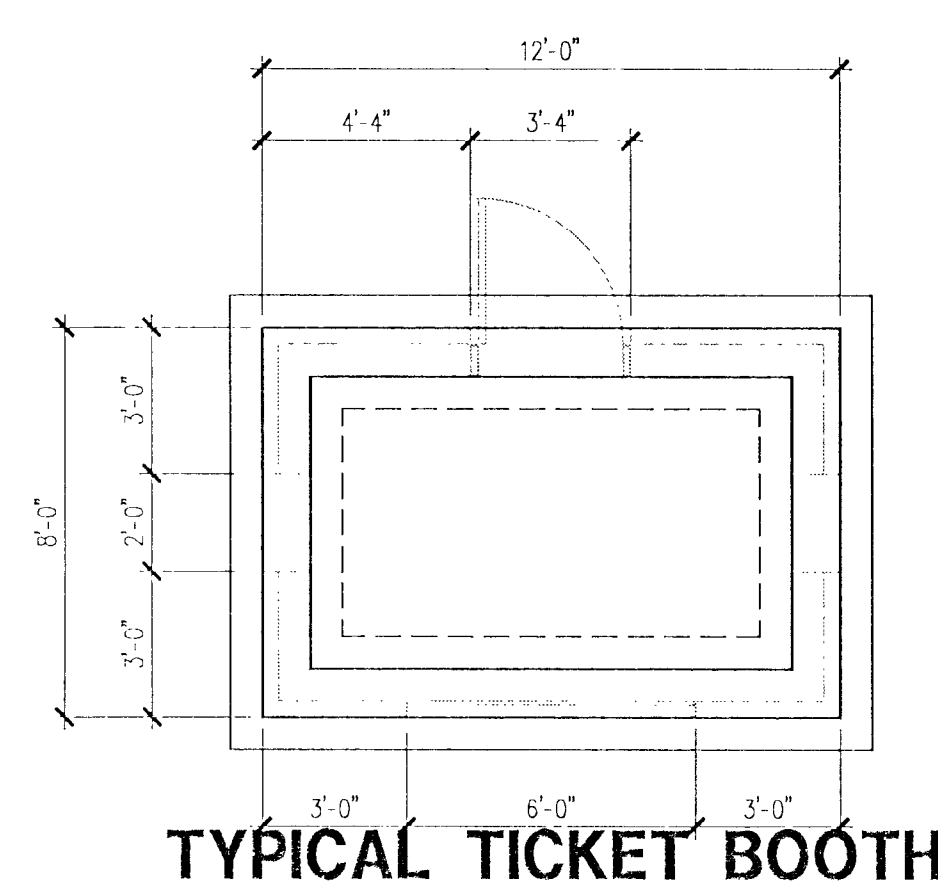

TYPICAL TICKET BOOTH

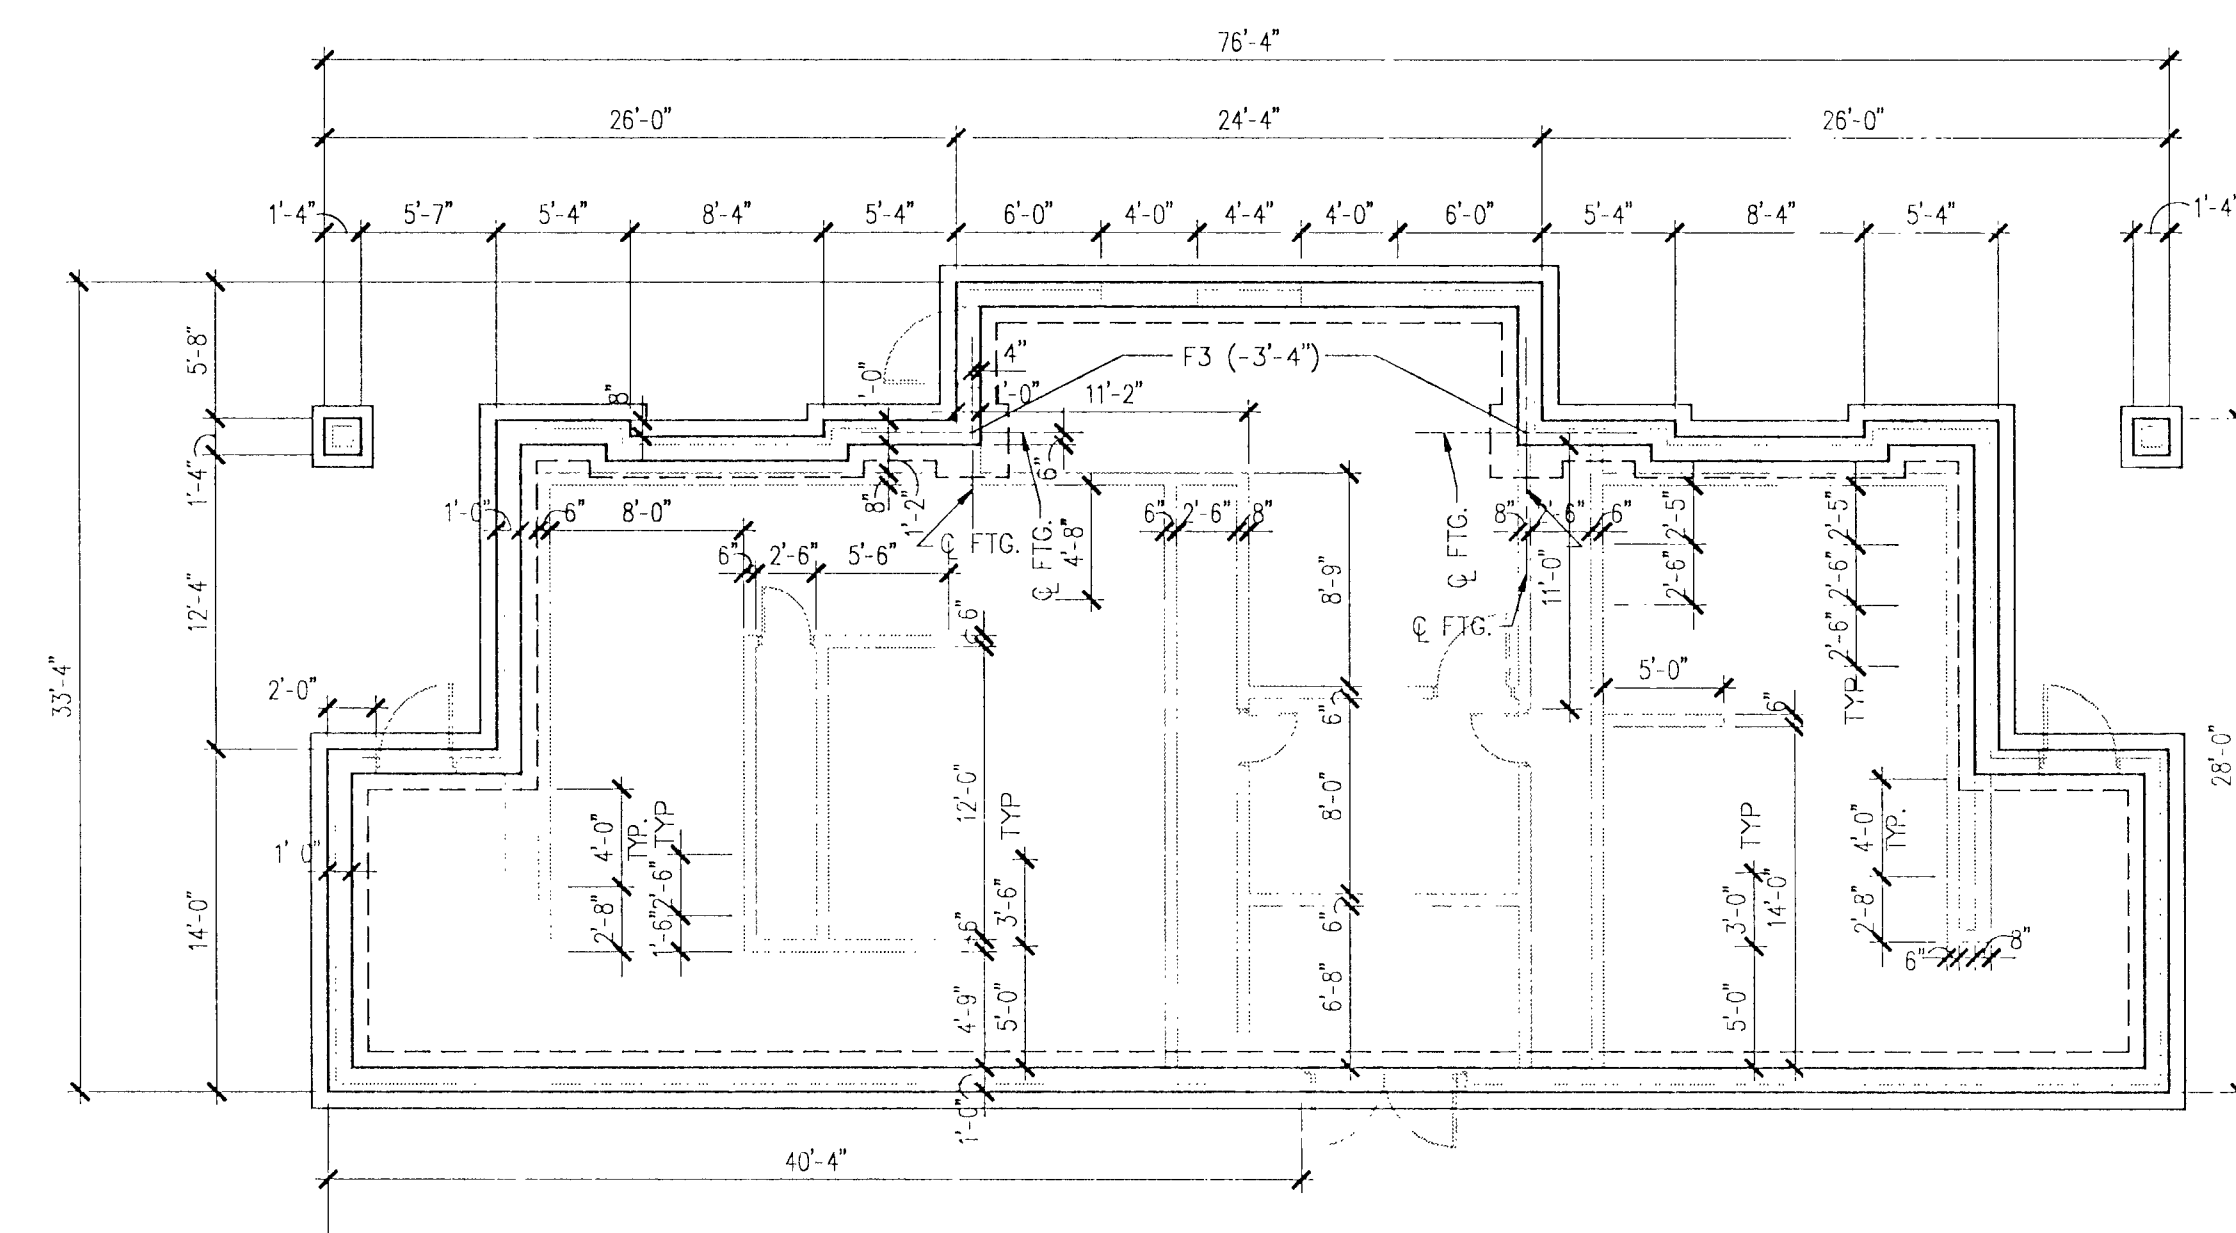

VISITOR TOILET AND CONCESSION
SCALE: 1/8" = 1'-0"



CERTIFIED

THE ODLE MCQUIRE & SHOOK CORPORATION
ARCHITECTURE • ENGINEERING • LANDSCAPE ARCHITECTURE • INTERIOR DESIGN
6765 NORTH STATE ROAD 37, POST OFFICE BOX 2149, BLOOMINGTON, INDIANA 47402, 812/878-2020
6275 ALLISON FORTY TRAIL, POST OFFICE BOX 34425, INDIANAPOLIS, INDIANA 46230, 317/842-0000

REVISIONS

© Copyright 1994 by THE ODLE MCQUIRE & SHOOK CORPORATION. Copyright includes architectural work, building design, plans or drawings, and specifications. Architectural work is the overall form or well as the arrangement and composition of space and elements in the design. Reproduction without written permission is prohibited.

MICHIGAN CITY SPORTS COMPLEX
AMES FIELD
MICHIGAN CITY, INDIANA

PROJECT NO. 93052
DATE: MAY 31, 1994
drawn by: BJM
checked by: JBF

S202

FOUNDATION AND FRAMING PLANS

1/8" = 1'-0"

DESIGN NOTES

- CONCRETE 28 DAY DESIGN STRENGTH:
CLASS E CONCRETE (ALL CONC. EXCEPT P.C. AND U.N.O.) 4000 P.S.I.
CLASS B CONCRETE (WALL FOOTING AND COLUMN) 3000 P.S.I.
- MASONRY 28 DAY DESIGN STRENGTH:
PRISM TEST STRENGTH 1500 P.S.I.
CONCRETE REINFORCING STEEL: A500
STRUCTURAL STEEL: A36
STRUCTURAL STEEL TUBING: A500
SOIL BEARING PRESSURES:
STADIUM & RESTROOM: 3000 P.S.F.
BRICK WALL FENCE: 2000 P.S.F.
- WIND LOAD: 85 MPH, EXPOSURE 1
SEISMIC LOAD: ZONE 1
LIVE LOAD:
ROOF: 40 P.S.F.
MECHANICAL ROOM: 150 P.S.F.
SEATING AND PUBLIC AREA: 100 P.S.F.

THIS BUILDING WAS DESIGNED IN ACCORDANCE WITH:
"THE INDIANA BUILDING CODE", INDIANA DEPARTMENT OF FIRE AND BUILDING SERVICES.
"BUILDING CODE REQUIREMENTS FOR REINFORCED CONCRETE", ACI 318
"DESIGN MANUAL FOR COMPOSITE DECKS, FORM DECKS AND ROOF DECKS", LATEST EDITION SDI.

FOUNDATION NOTES

- AFTER STRIPPING OF THE TOPSOIL, THE EXPOSED SUBGRADE SHALL BE PROOFROLLED WITH A MEDIUM WEIGHT ROLLER OR OTHER APPROVED EQUIPMENT TO DETERMINE IF ANY POCKETS OF SOFT COMPRESSIBLE SOILS EXIST BENEATH THE EXPOSED SUBGRADE. WHEREVER SUCH MATERIAL IS ENCOUNTERED, THE AREA SHALL BE UNDERCUT TO SUITABLE SOILS.
- AFTER STRIPPING OF THE TOP SOIL, WHERE FOOTING ELEVATION IS HIGHER THAN THE EXPOSED SUBGRADE, THE ENGINEERED FILL SHALL BE PLACED ON TOP OF THE APPROVED EXPOSED SUBGRADE TO THE UNDERNEATH OF THE FOOTING. ALL ENGINEERED FILL BENEATH THE FLOOR SLABS AND FOOTINGS SHALL BE COMPACTED TO A DRY DENSITY OF AT LEAST 93% OF THE MODIFIED PROCTOR MAX. DRY DENSITY (ASTM D-1557). THIS MINIMUM COMPACTION REQUIREMENT SHALL BE INCREASED TO 95 PERCENT FOR FILL SUPPORTING FOOTINGS. PLACING AND COMPACTION OF ENGINEERED FILL SHALL BE OVERSEEN BY THE INDEPENDENT TESTING LABORATORY.
- FOOTING NOT SUPPORTED BY ENGINEERED FILL SHALL BEAR ON FIRM UNDISTURBED MATERIAL. ALL FOOTING EXCAVATIONS SHALL BE INSPECTED BY THE INDEPENDENT TESTING LABORATORY TO ASSURE THE ADEQUATE BEARING CAPACITY FOR WHICH THE FOOTINGS WERE DESIGNED. IF UNSUITABLE MATERIAL IS FOUND, THE AREA SHALL BE UNDERCUT TO SUITABLE SOILS AND THEN FILLED WITH LEAN CONCRETE OR COMPACTED ENGINEERING FILL.
- ALL FOOTINGS SUBJECTED TO OUTSIDE WEATHER CONDITIONS SHALL BE LOCATED AT LEAST 4 FEET BELOW FINAL EXTERIOR GRADE AT ANY GIVEN POINT FOR FROST PROTECTION UNLESS OTHERWISE INDICATED.
- BACK FILL ALONG THE FOUNDATION AND BRICK WALL FENCE FOUNDATION SHALL BE COMPACTED TO A DRY DENSITY OF 93% OF THE MODIFIED PROCTOR MAX. DRY DENSITY (ASTM D-1557).
- IF DEWATERING IS REQUIRED, SUMPS SHALL NOT BE PLACED WITHIN THE FOOTING OR GRADE BEAM EXCAVATION.
- SEE THE SUBSURFACE INVESTIGATION & FOUNDATION RECOMMENDATIONS REPORT BY K & S TESTING AND ENGINEERING, INC. FOR STRIPPING TOPSOIL, PROOFROLLING, COMPACTING FILL, TESTING AND SUPERVISION.

CONCRETE NOTES

- REINFORCING STEEL PLACING DRAWINGS AND BAR LISTS SHALL CONFORM TO THE AMERICAN CONCRETE INSTITUTE'S "DETAILS AND DETAILING OF CONCRETE REINFORCEMENT" (ACI 315) AND "MANUAL OF ENGINEERING AND PLACING DRAWINGS FOR REINFORCED CONCRETE STRUCTURES" (ACI 315R). ALL BAR AND MESH SUPPORTS MUST BE CLEARLY DETAILS.
- ALL REINFORCING STEEL DETAILS SHALL BE IN ACCORDANCE WITH THE ACI "BUILDING CODE REQUIREMENTS FOR REINFORCED CONCRETE" (ACI 318).
- PROVIDE SHEAR KEYS IN ALL THE CONSTRUCTION JOINTS.
- CENTER ALL FOOTINGS ON WALL, PIER OR COLUMN ABOVE UNLESS OTHERWISE INDICATED.
- PROVIDE 0.5% OF TOTAL TONNAGE OF REINFORCING STEEL TO BE FABRICATED AND PLACED AS DIRECTED BY THE ARCHITECT/ENGINEER.

CONCRETE MASONRY NOTES

- FILL CORES OF CONCRETE BLOCKS SOLID WITH CONCRETE OR USE SOLID BLOCKS FOR AN AREA OF 16 INCHES X 16 INCHES BELOW ALL LINTELS AND BEAMS SUPPORTED ON MASONRY WALLS UNLESS OTHERWISE INDICATED.
- REINFORCING BARS IN BOND BEAMS MUST BE CONTINUOUS AT INTERSECTIONS OR CHANGES IN DIRECTIONS OF WALLS.
- WEBS OF CONCRETE BLOCKS WITH CORES TO BE GROUTED SOLID SHALL BE BUTTERED WITH MORTAR.
- ALL WALLS SHALL BE TOPPED WITH CONTINUOUS BOND BEAM.

STEEL DECK NOTES

- STEEL DECK CONSTRUCTION SHALL CONFORM TO THE LATEST EDITION OF THE STEEL DECK INSTITUTE'S "DESIGN MANUAL FOR COMPOSITE DECKS, FORM DECKS AND ROOF DECKS".
- ALL DECK SHALL BE THREE OR MORE SPANS CONTINUOUS WHERE POSSIBLE.
- OPENINGS GREATER THAN 12" THROUGH THE ROOF DECK SHALL BE FRAMED WITH ANGLES 3"x3"x5/16" ON FOUR SIDES.

WELD NOTES

- E70XX ELECTRODES SHALL BE USED FOR ALL WELDS.

MISCELLANEOUS NOTES


- EACH CONTRACTOR SHALL VERIFY THE SIZE AND LOCATION OF DUCT OPENINGS, GRILLS, LOUVERS, ETC. WITH THE MECHANICAL TRADES BEFORE PROCEEDING WITH THE WORK.

STEEL ROOF DECK:

- 1 1/2 INCH STANDARD DECK: WIDE RIB DECK, 0.0295 INCH DESIGN THICKNESS AND 22 GAGE WITH MINIMUM SECTION PROPERTIES: I = 0.167 IN⁴/FT., S_x = 0.186 IN³/FT. AND S_y = 0.194 IN³/FT.


P.C. WALL PANEL NOTES

- PROVIDE SOLID CORE AT RELIEVING ANGLE.
- EMBED 3/8"x5" CONTINUOUS PLATE AT TOP OF WALL FOR ROOF TRUSS ANCHORAGE.

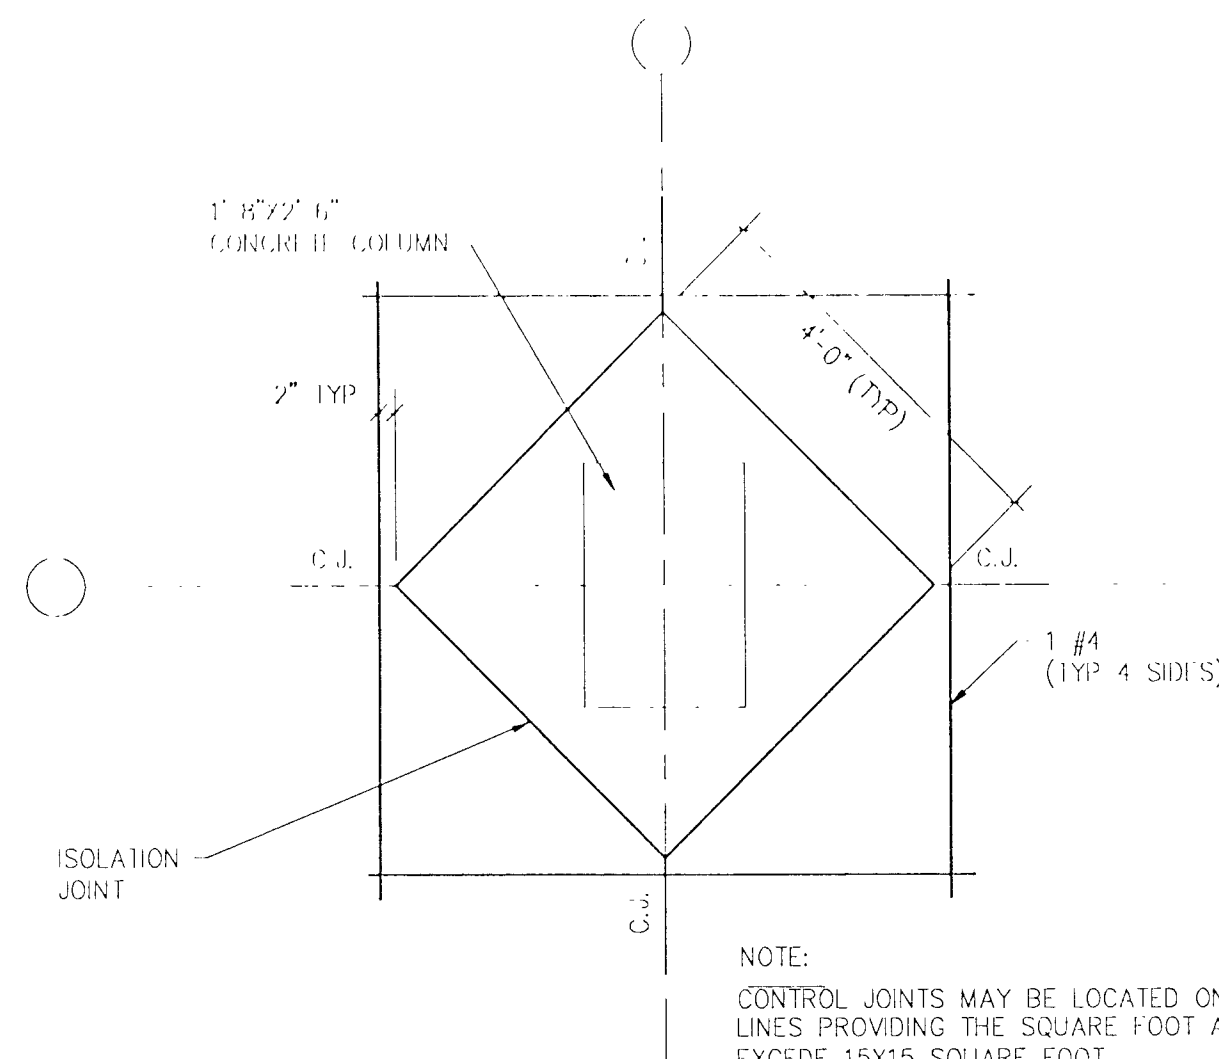


ISOLATION JOINT AT COLUMN

SCALE: 1/2" = 1'-0"

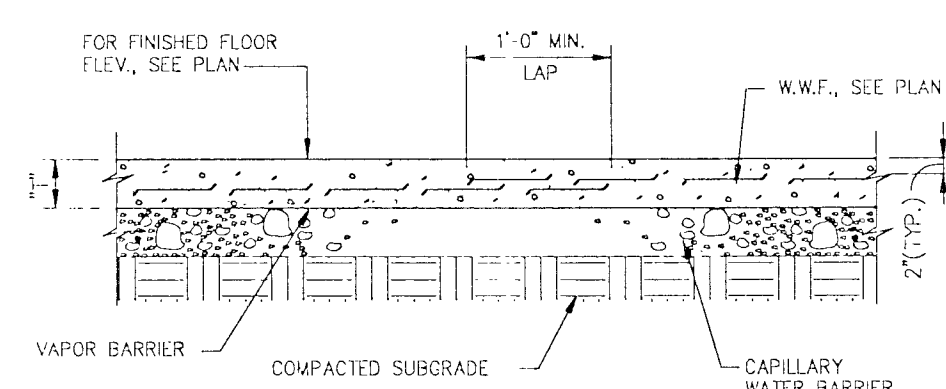


TYPICAL SLAB ON GRADE

CONSTRUCTION

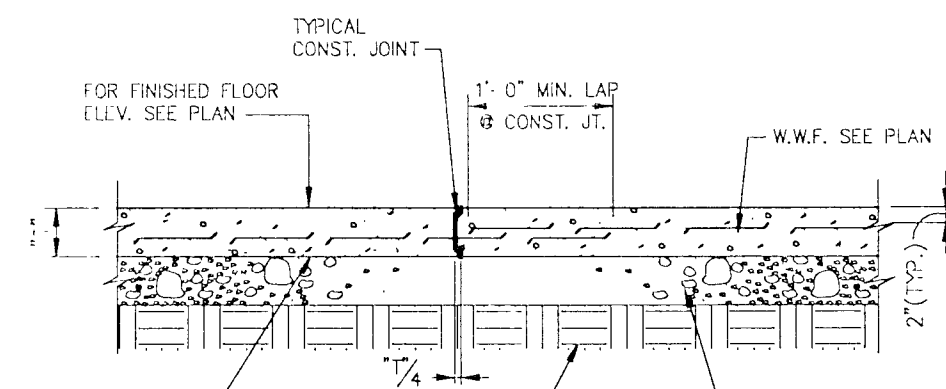


TYPICAL SLAB ON GRADE

CONSTRUCTION JOINT

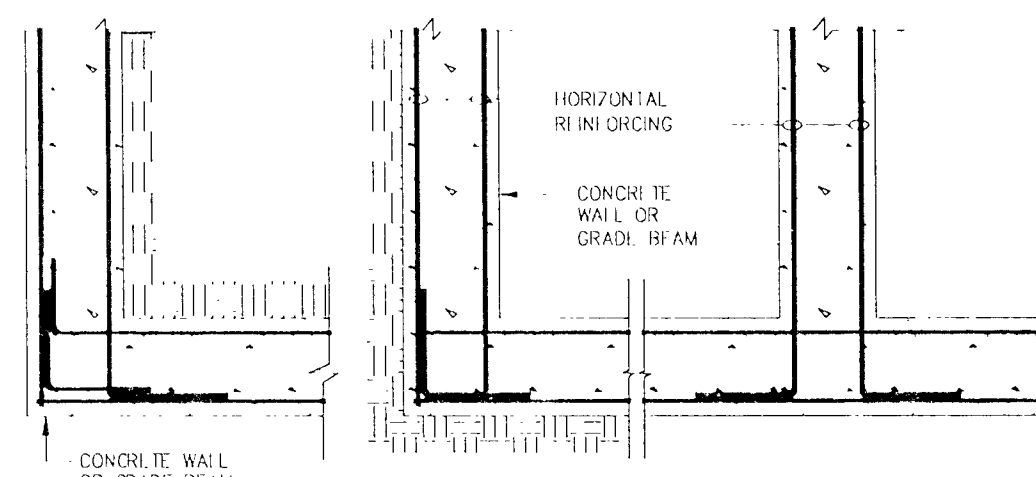


TYPICAL CORNER DETAIL FOR

HORIZONTAL REINFORCING

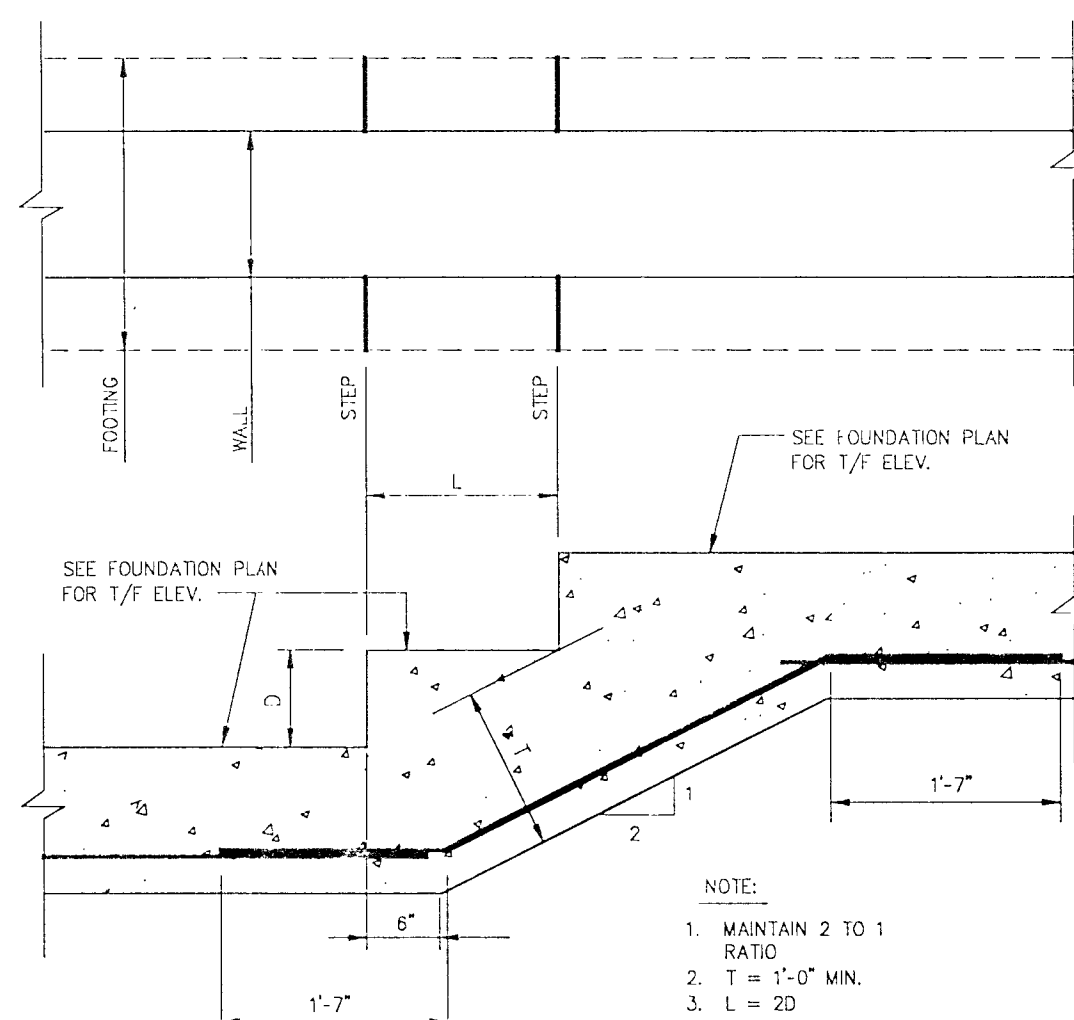


TYPICAL STEP FOOTING DETAIL

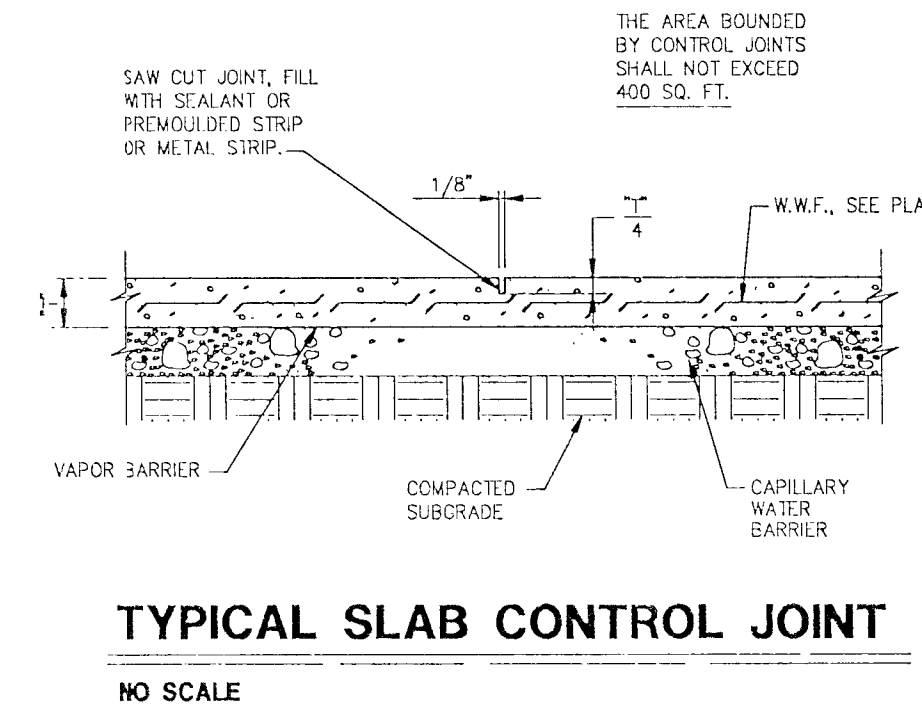


TYPICAL SLAB CONTROL JOINT

NO SCALE

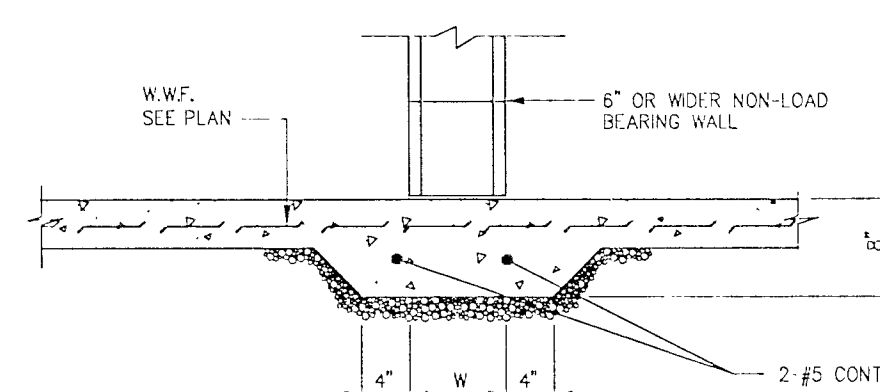


TYPICAL THICKENED SLAB

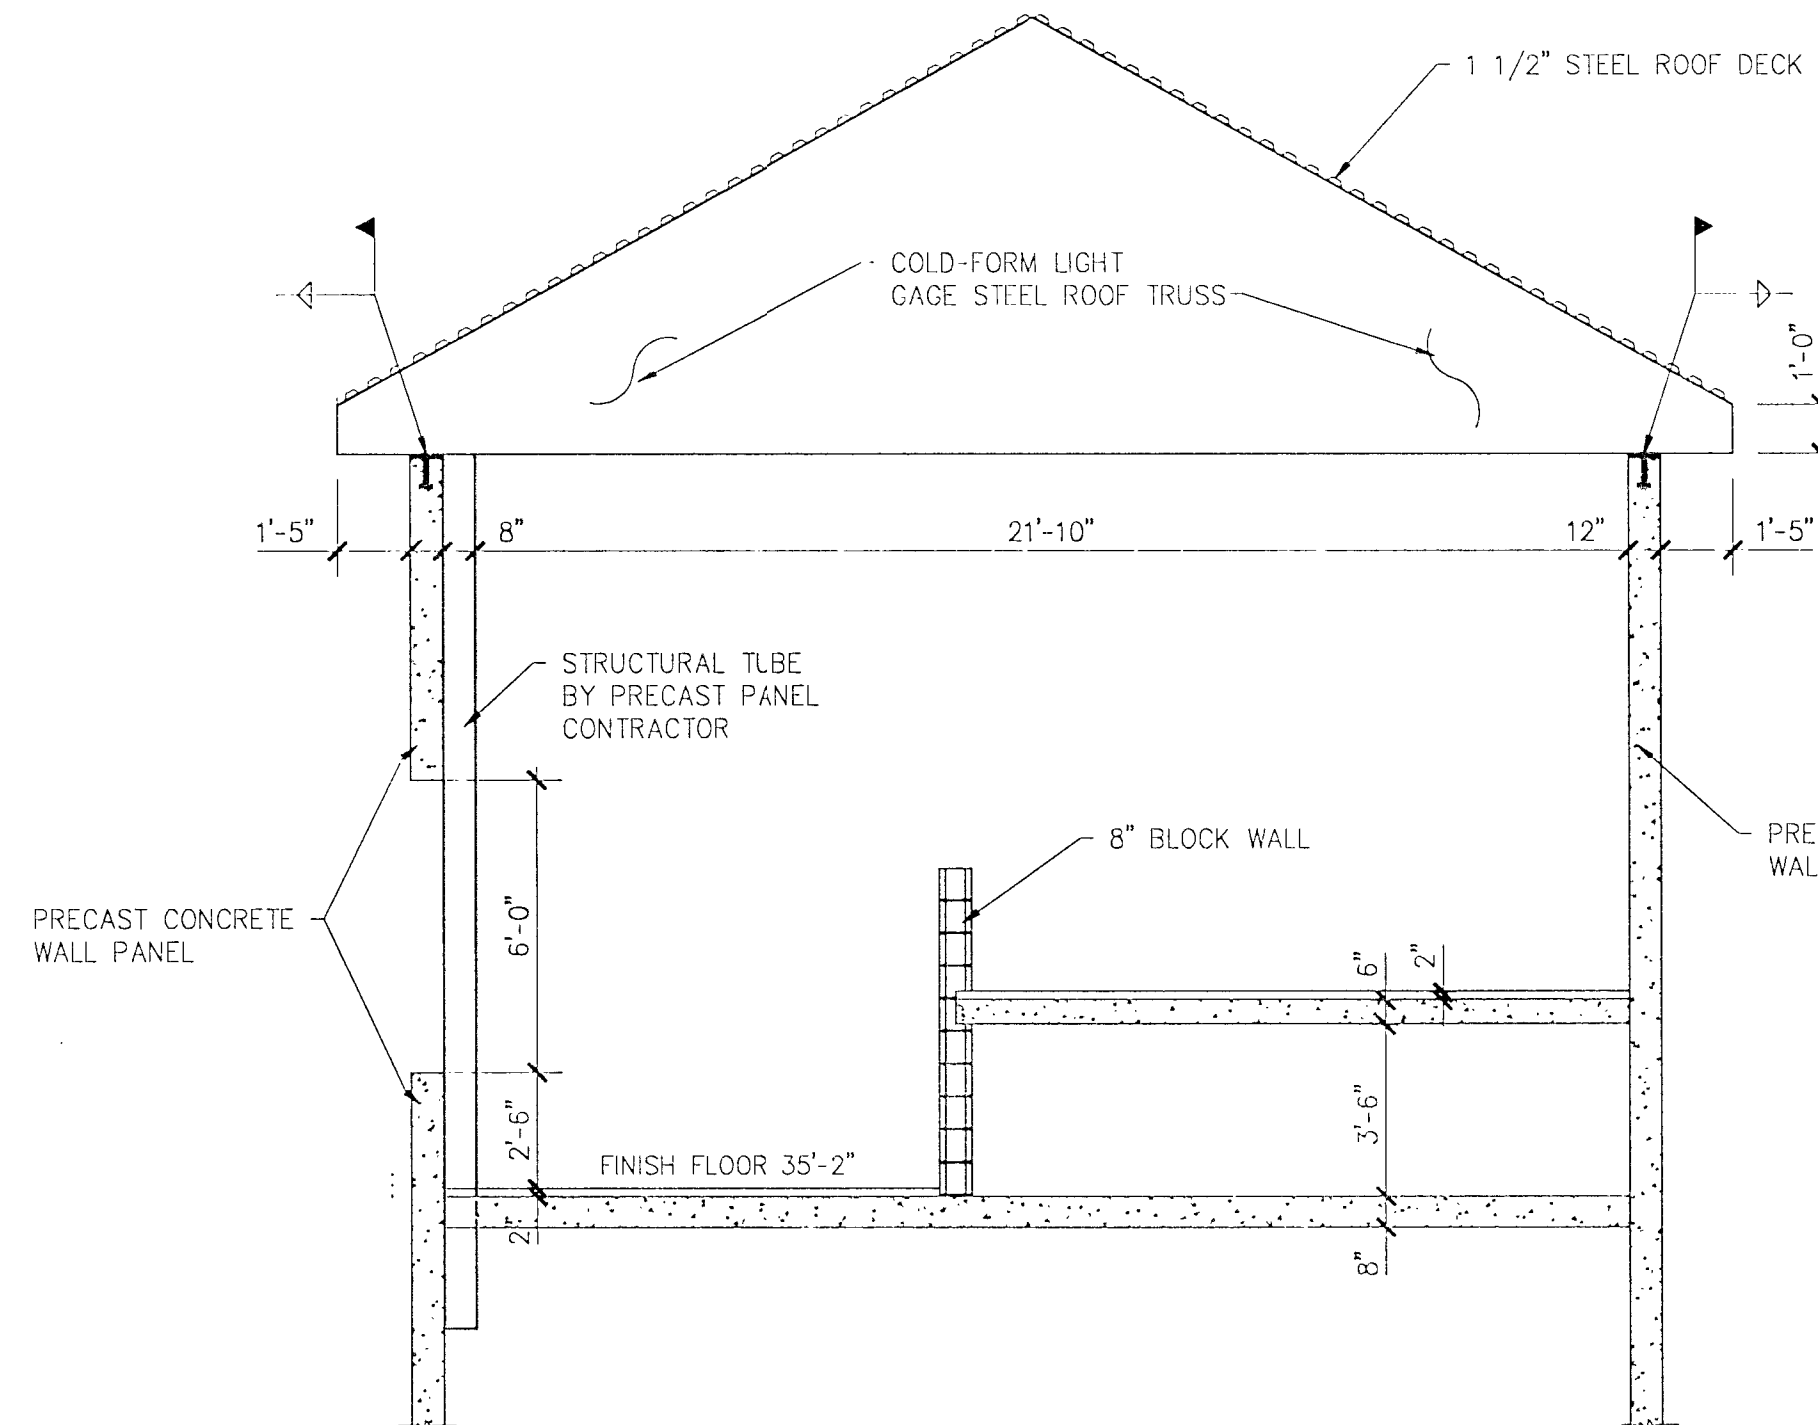


SECTION

NOT TO SCALE

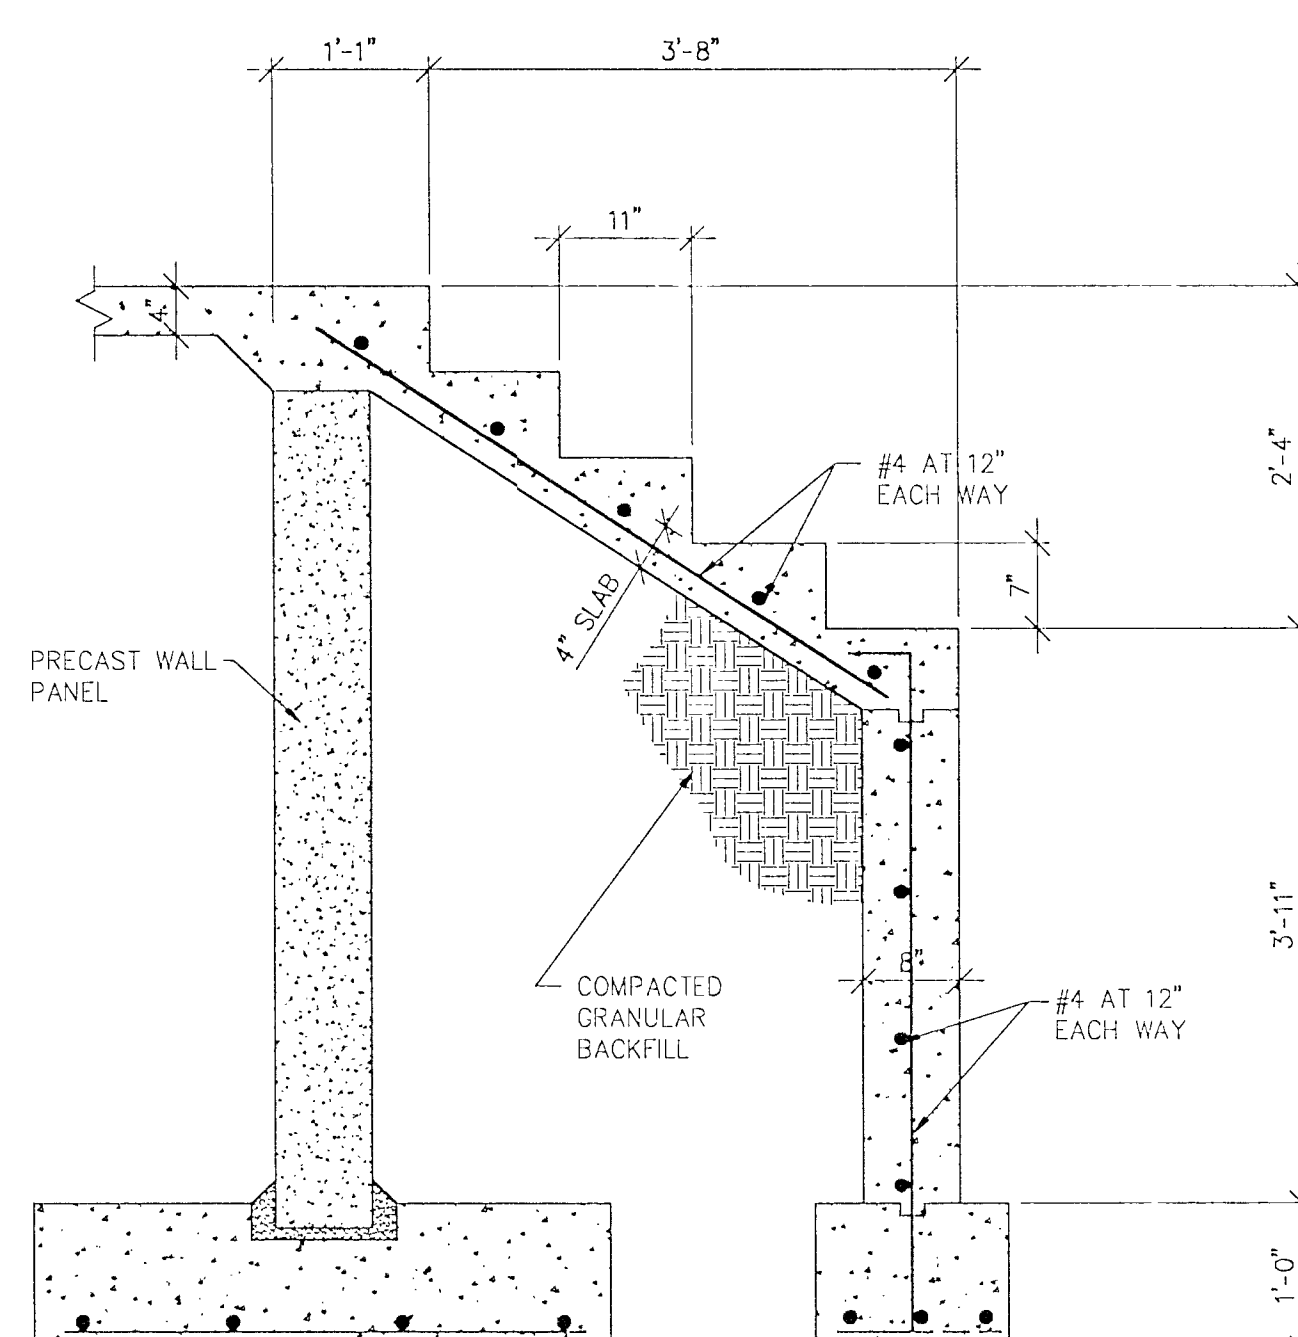


SECTION

SCALE: 3/4" = 1'-0"

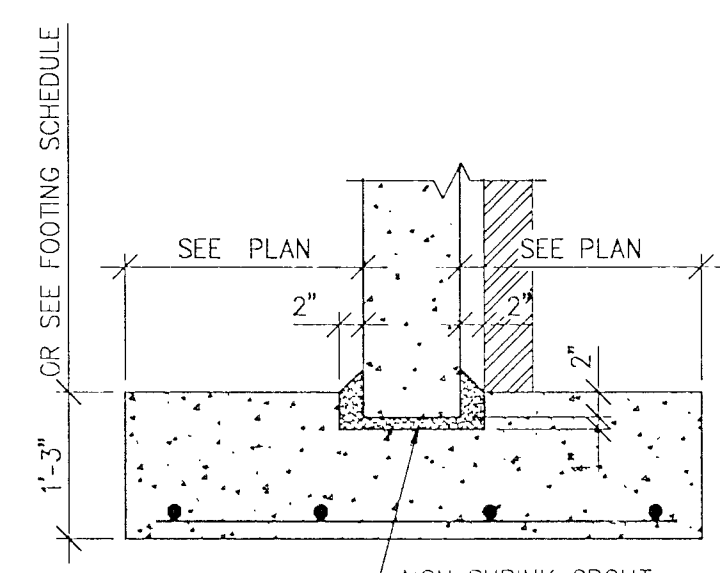


TYPICAL P.C. WALL PANEL FOOTING

NOT TO SCALE

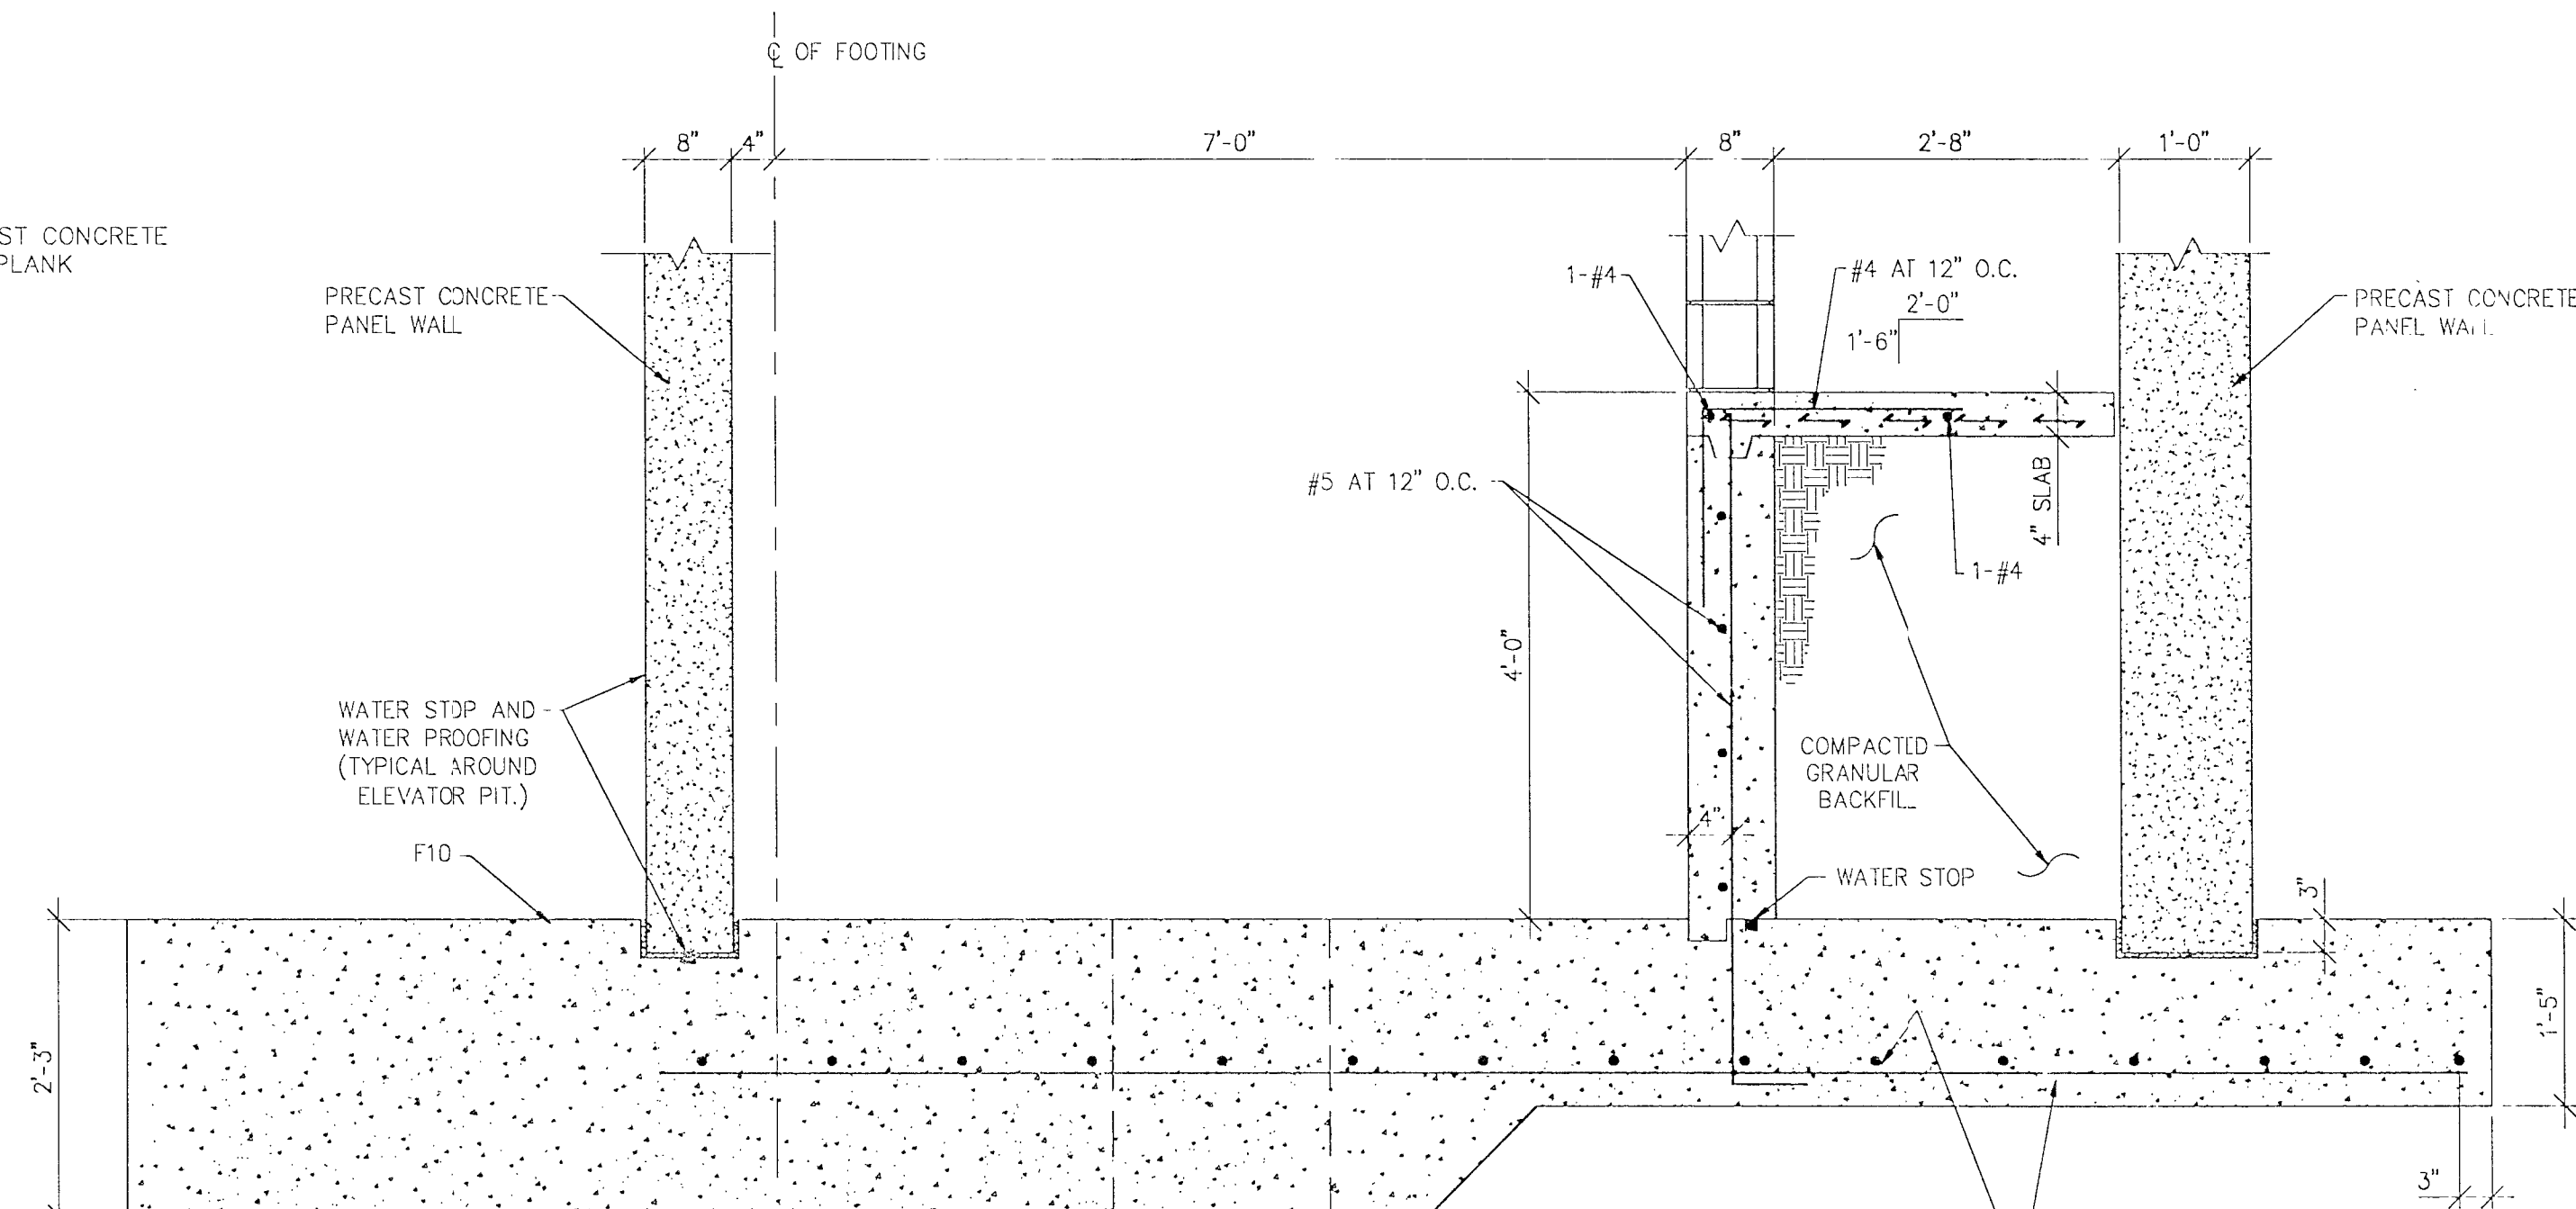


SECTION

SCALE: 3/4" = 1'-0"

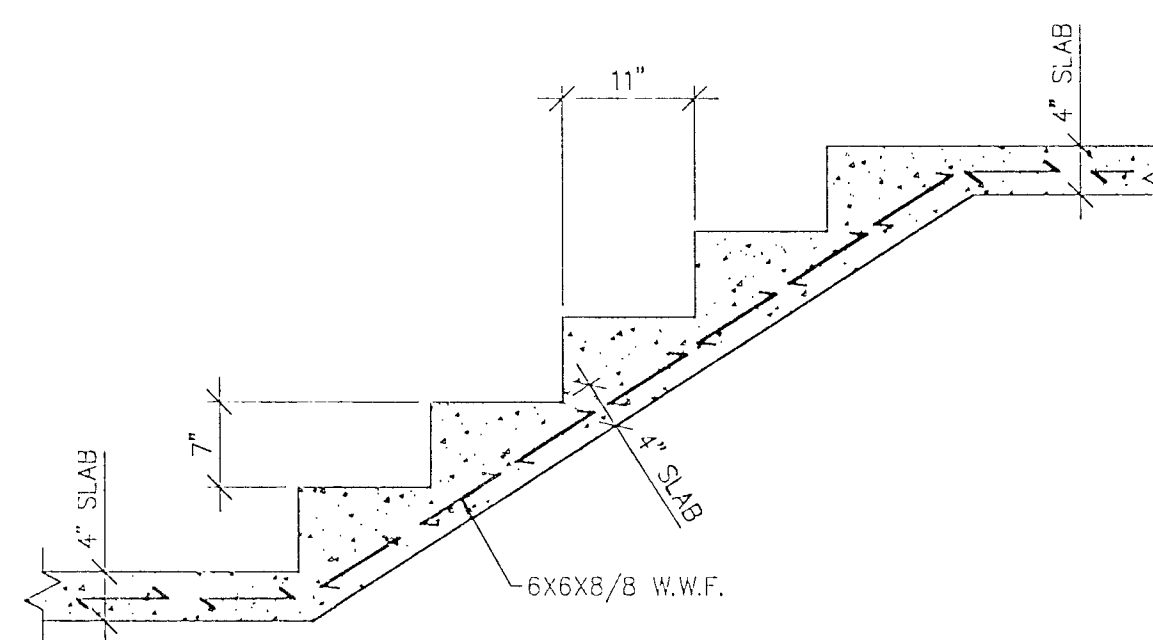


SECTION

SCALE: 3/4" = 1'-0"

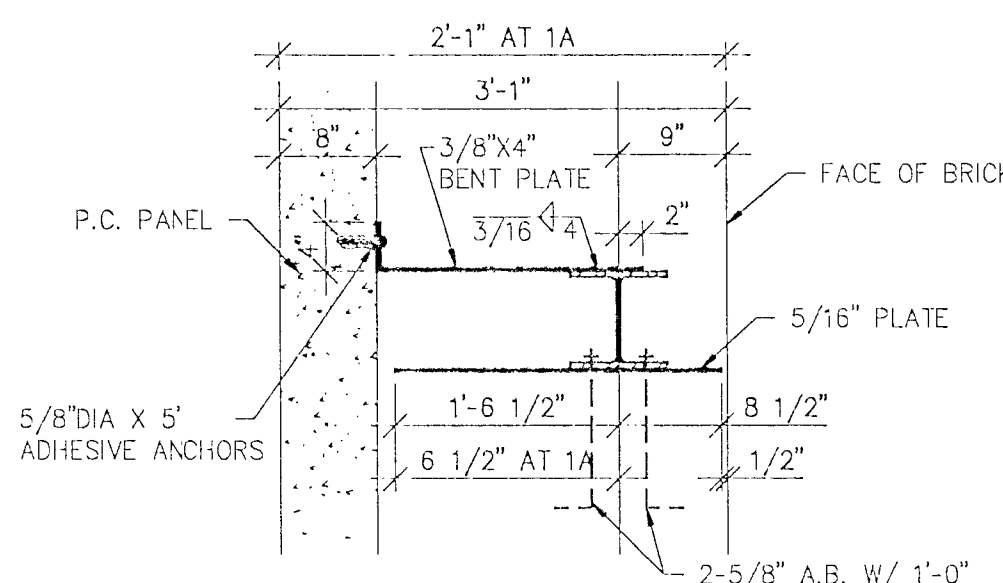


SECTION

SCALE: 3/4" = 1'-0"

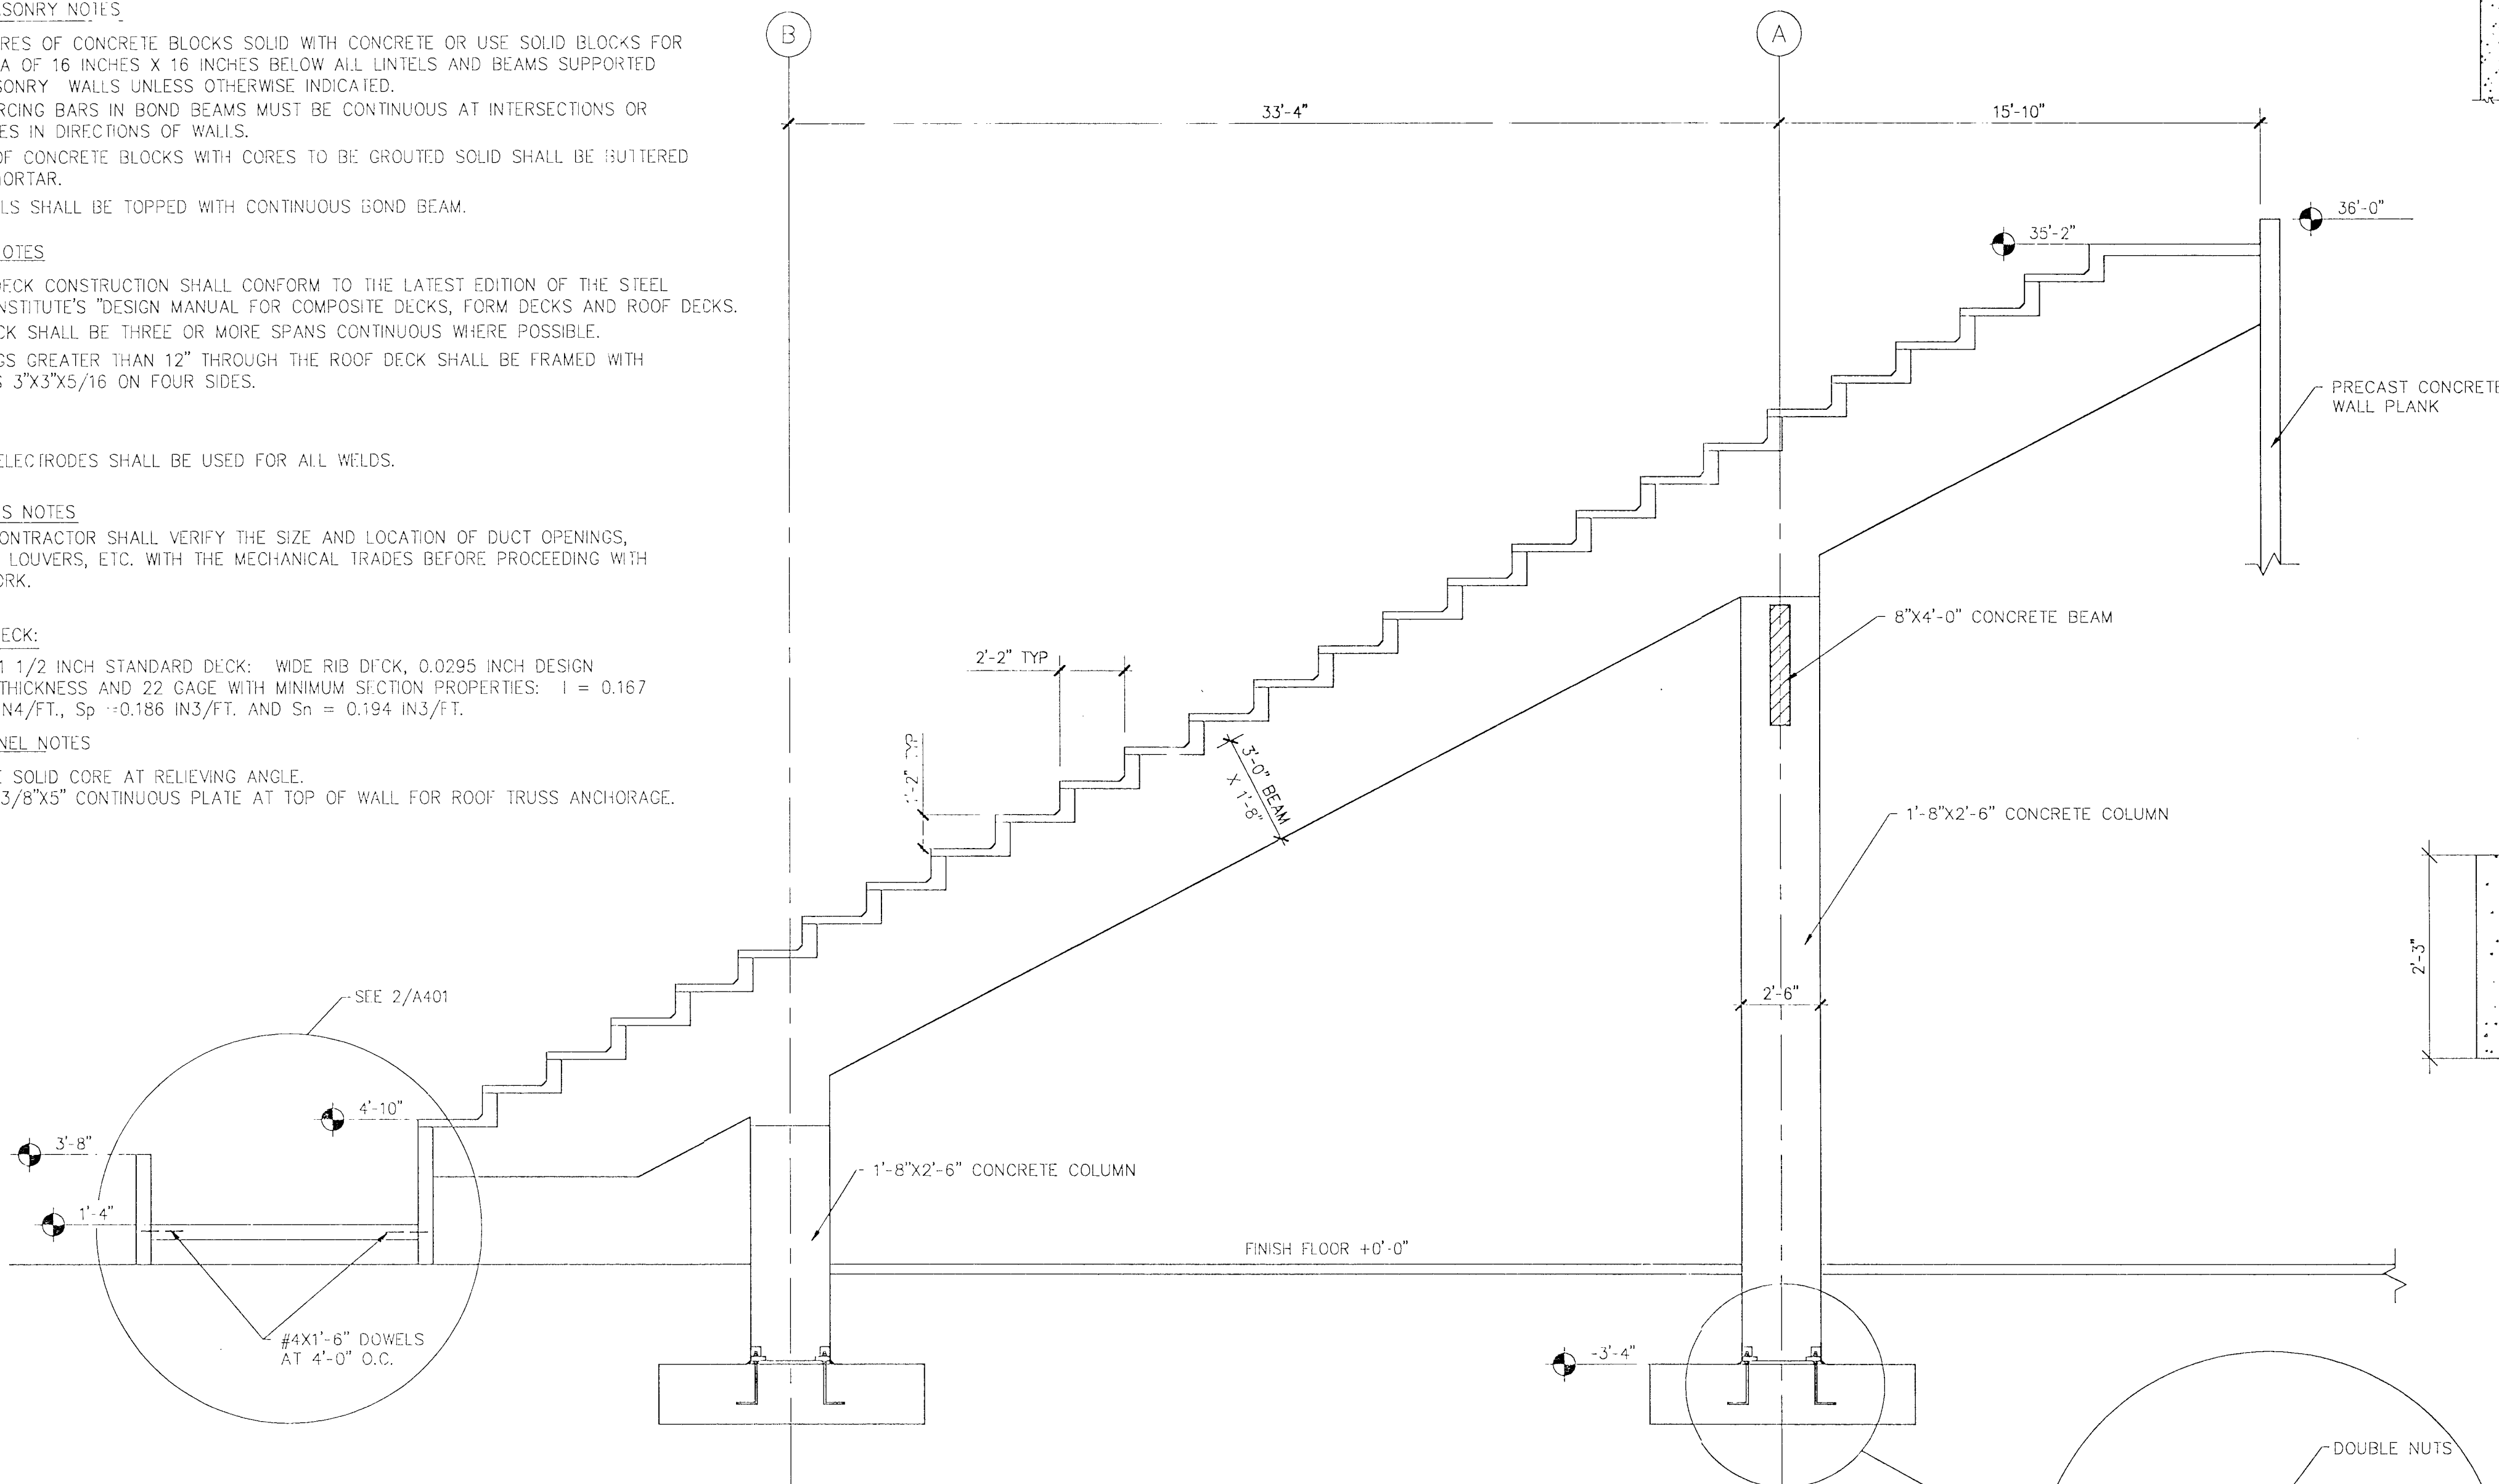

SECTION


SCALE: 3/4" = 1'-0"

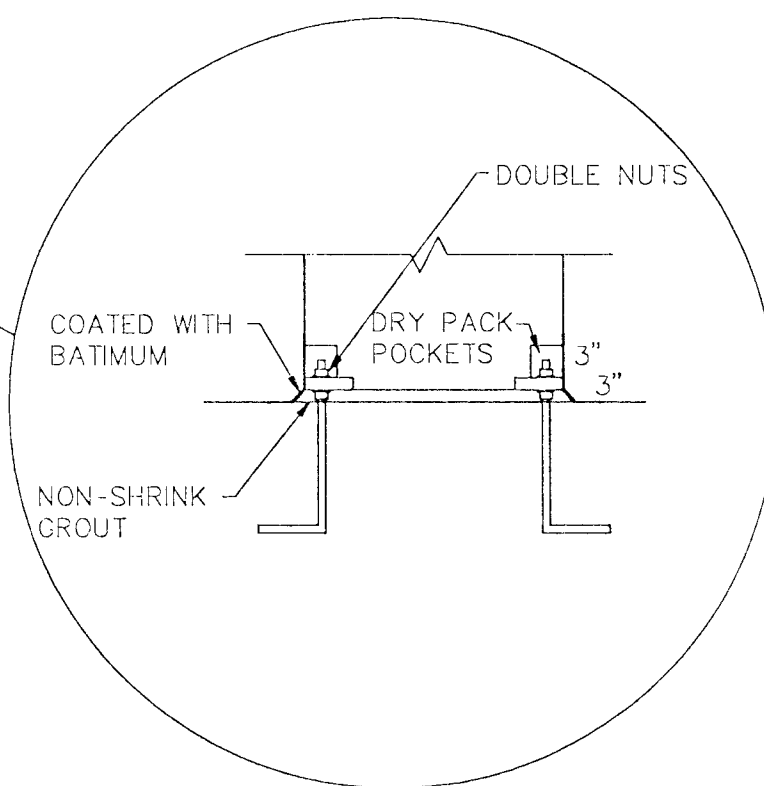

DETAIL

SCALE: 3/4" = 1'-0"

PLANNING & DESIGN GROUP, INC. 27-04 15-06-14

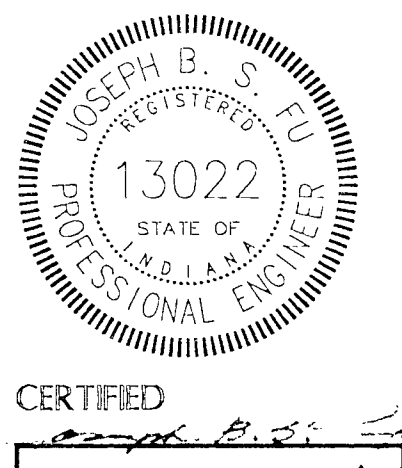

CERTIFIED

THE ODLE MCGUIRE & SHOOK CORPORATION
ARCHITECTURE • ENGINEERING • LANDSCAPE ARCHITECTURE • INTERIOR DESIGN
5755 NORTH STATE ROAD, 371 EAST OFFICE BOX 2743, BLOOMINGTON, INDIANA 47403, 812/875-0700
5755 NORTH STATE ROAD, 371 EAST OFFICE BOX 2743, BLOOMINGTON, INDIANA 47403, 812/875-0700

REVISIONS

© Copyright 1994 by THE ODLE MCGUIRE & SHOOK CORPORATION. Copyright includes architectural work, building design, plans or drawings, and specifications. Architectural work is the overall form or well as the arrangement and composition of space and elements in the design. Reproduction without written permission is prohibited.

MICHIGAN CITY SPORTS COMPLEX
AMES FIELD
MICHIGAN CITY, INDIANA

 
 
 
 
 
 
 
 
 
 
 
 
 
 
 
 
 
 
 
 
 
 
 
 
 
 
 
 
 
 
 
 
 
 
 
 
 
 
 
PROJECT NO. 93052
DATE: MAY 31, 1994
drawn by: JAW
checked by: JBF

S401

SECTIONS AND DETAILS

1/8" = 1'-0"









































MECHANICAL SYMBOLS

SYMBOL	DESCRIPTION	SYMBOL	DESCRIPTION
	GATE VALVE		MAKE-UP WATER
	CHECK VALVE		HEATING WATER SUPPLY *
	BUTTERFLY VALVE		HEATING WATER RETURN *
	GLOBE VALVE		CHILLED WATER SUPPLY *
	MEASURING/BALANCING VALVE		CHILLED WATER RETURN *
	BALL VALVE		CONDENSER WATER SUPPLY *
	CONTROL VALVE, 2-WAY		CONDENSER WATER RETURN *
	CONTROL VALVE, 3-WAY		BOILER BLOW OFF LINE
	PRESSURE REDUCING VALVE		REFRIGERANT LIQUID *
	SOLENOID VALVE		REFRIGERANT SUCTION *
	RELIEF (R), SAFETY (S), VALVE		GLYCOL SUPPLY *
	PIPE, UP (RISER)		GLYCOL RETURN *
	PIPE, DOWN (DROP)		FUEL OIL SUPPLY *
	CONNECTION, TOP		FUEL OIL RETURN *
	CONNECTIONS, BOTTOM		FUEL OIL GAUGE
	CONCENTRIC REDUCER		FUEL OIL VENT
	ECCENTRIC REDUCER		CONDENSATE DRAIN LINE **
	UNION		CONDENSATE PUMP DISCHARGE **
	PIPE ANCHOR		VACUUM PUMP DISCHARGE **
	PIPE GUIDE		LOW PRESSURE STEAM **
	Y-STRAINER		LOW PRESSURE RETURN **
	BASKET STRAINER		MEDIUM PRESSURE STEAM ** (PRESSURE INDICATED)
	AIR ELIMINATOR		MEDIUM PRESSURE RETURN ** (PRESSURE INDICATED)
	EXPANSION JOINT		HIGH PRESSURE STEAM ** (PRESSURE INDICATED)
	FLEXIBLE CONNECTOR		HIGH PRESSURE RETURN ** (PRESSURE INDICATED)
	FLOWMETER, VENTURI		
	FLOW SWITCH		
	PRESSURE GAUGE		
	THERMOMETER		
	TRAP (INDICATE TYPE)		
	TEST PLUG		
	AUTOMATIC FLOW CONTROL VALVE WITH PRESSURE TAPS		
	BUTTERFLY VALVE WITH MEMORY STOP		
	BALL VALVE WITH MEMORY STOP		

MECHANICAL GENERAL NOTES:

- M.C. SHALL REFER TO THE SPECIFICATIONS FOR REQUIREMENTS RELATING TO EQUIPMENT QUALITY, CONSTRUCTION AND FINISH OF MATERIALS.
- THESE DRAWINGS INDICATE REQUIRED SIZES AND POINTS OF TERMINATION FOR PIPING, DUCTWORK, CONDUT, ETC. THE EQUIPMENT SHOWN ILLUSTRATES SUGGESTED ROUTING, BUT ALL NECESSARY OFFSETS MAY NOT BE SHOWN. CONTRACTOR SHALL INSTALL HIS WORK IN A MANNER THAT WILL CONFORM WITH THE STRUCTURE. CONTRACTOR SHALL AVOID OBSTRUCTIONS, PRESERVE HEADROOM AND MAINTAIN MAXIMUM CLEARANCE WITHOUT FURTHER INSTRUCTION FROM THE ENGINEER OR ADDITIONAL COST TO THE OWNER.
- ALL DUCTWORK, PIPING AND VALVES SHALL BE CONCEALED ABOVE CEILINGS AND WITHIN WALLS IN FINISHED AREAS UNLESS OTHERWISE INDICATED.
- ALL VALVES, COILS, DAMPERS, ETC., SHALL BE INSTALLED ALLOWING EASY ACCESS TO THEM. AREAS ADJACENT TO THE ACCESS PANELS SHALL BE CLEAR OF ANY OBSTRUCTIONS.
- CONTRACTOR SHALL BE GUIDED BY THE ARCHITECT'S REFLECTED CEILING PLAN FOR EXACT LOCATION OF DIFFUSERS, REGISTERS, AND GRILLES SHOWN OR COVERED BY THESE DRAWINGS.
- ARROWS ON THE HOT WATER AND CHILLED WATER MAINS INDICATE THE DIRECTION OF FLOW. PITCH MAINS UPWARD A MINIMUM OF 1" PER 50'-0" IN THE DIRECTION OF FLOW. ARROWS ON STEAM AND CONDENSATE PIPING AND DRAIN LINES INDICATE THE DOWNWARD PITCH OF THE PIPING.
- INSTALL AIR VENTS AT ALL HIGH POINTS AND DRAINS AT ALL LOW POINTS OF WATER PIPING SYSTEMS.
- PIPING BRANCHES TO EQUIPMENT SHALL HAVE THE SAME SIZE VALVES AND FITTINGS AS THAT OF THE LINE SIZE WITH THE EXCEPTION OF TEMPERATURE CONTROL VALVES AND STEAM TRAPS.
- PIPE "SWING" CONNECTIONS, WITH UNIONS OR FLANGES, SHALL BE MADE EXTERNAL TO COILS OR A TUBE BUNDLE TO FACILITATE REMOVAL OF THAT ITEM WITHOUT DISTURBING THE BRANCH VALVES AND/OR PIPING.
- TRAPS, VALVES AND FITTINGS SERVING ENCLOSED HEATING AND/OR COOLING UNITS SHALL BE CONCEALED IN THE CABINET OR ENCLOSURE BEHIND AN ACCESS DOOR.
- ALL GATE VALVES, STRAINERS, PIPING AND FITTINGS IN TEMPERATURE CONTROL VALVE STATIONS AND PRESSURE REDUCING VALVE STATIONS SHALL BE ONE PIPE SIZE LARGER THAN CONTROL OR REDUCING VALVES.
- ALL EXPANSION LOOPS (STEAM AND WATER) SHALL BE "COLD SPRUNG" UNLESS OTHERWISE NOTED.
- DUCTS PENETRATING FLOOR SLABS AND (OR) WALLS SHALL BE SEALED AS REQUIRED BY CODE. DUCTS PENETRATING FIRE RATED WALL AND (OR) FLOOR SHALL HAVE OPENING AROUND DUCT SEALED WITH A MATERIAL HAVING THE SAME FIRE RATING AS THE WALL OR FLOOR.

                                        PLUMBING SYMBOLS






















DESCRIPTION	NEW	EXISTING
DOMESTIC COLD WATER		
DOMESTIC SOFT COLD WATER		
DOMESTIC 140° HOT WATER		
DOMESTIC 120° HOT WATER		
DOMESTIC HOT WATER RETURN		
TEMPERED WATER		
SANITARY SEWER		
SANITARY WASTE		
VENT		
GAS SERVICE		
FIRE PROTECTION WATER SERVICE		
PIPE BELOW GRADE		
BRANCH OFF BOTTOM		
BRANCH OFF TOP		
BRANCH OFF SIDE		
RISER DOWN (ELBOW)		
RISER UP (ELBOW)		
CAPPED PIPE OR TEE		
FLOW IN DIRECTION OF ARROW		
SLOPE IN DIRECTION OF ARROW		
WATER HAMMER ARRESTER		
SHUT-OFF VALVE		
BALL VALVE		
CHECK VALVE		
STRAINER		
THERMOMETER		
UNION (DIELECTRIC OR AS NOTED)		
THERMASTATIC MIXING VALVE		
BU-B-IN--WELL W/CAPILLARY		
AQJASTAT		
TEMPERATURE & PRESSURE RELIEF VALVE		
CLEANOUT ON SUSPENDED PIPE		
WALL CLEANOUT		
FLOOR CLEANOUT		
GAS COCK		
SOLENOID GAS COCK		
UNDERGROUND GATE VALVE W/ROAD BOX		
POST INDICATOR		
FIRE DEPARTMENT CONNECTION (FREE STANDING)		
FIRE HYDRANT		
EXTERIOR CLEANOUT		
SANITARY MANHOLE		
SANITARY MANHOLE W/INSIDE DROP		
SANITARY MANHOLE W/OUTSIDE DROP		
WALL HYDRANT		
SUPERVISED FLOW CONTROL VALVE (FIRE PROTECTION)		
FLOW SWITCH (FIRE PROTECTION)		
CONNECTION OF NEW TO EXISTING		


- ALL RECTANGULAR SHEETMETAL DUCT SIZES SHOWN ARE INSIDE DIMENSIONS. ALL ROUND DUCT SIZES SHOWN ARE INSIDE DIAMETERS. ALLOWANCE FOR ACOUSTICAL LINER WHERE INDICATED ON DRAWINGS MUST BE ADDED TO OBTAIN OUTSIDE DIAMETER SHEETMETAL DIMENSION.
- INSTALL VOLUME DAMPER AT EACH BRANCH TAKE-OFF FROM MAIN SUPPLY DUCTS.
- INSTALL VOLUME DAMPER AT EACH ZONE CONNECTED TO ZONING TYPE AIR HANDLING UNIT.
- ALL WALL THERMOSTATS, TEMPERATURE SENSORS, AND (OR) HUMIDISTS SHALL BE APPROXIMATELY 4'-7" ABOVE FINISHED FLOOR TO BOTTOM AND LINED UP VERTICALLY WITH LIGHT SWITCHES UNLESS OTHERWISE NOTED OR DIRECTED BY THE ARCHITECT.
- PROVIDE MINIMUM 10'-0" SEPARATION BETWEEN SEWER AND WATER LINES. IF 10'-0" SEPARATION CANNOT BE MAINTAINED, THE SEWER MUST BE CONSTRUCTED OF WATER WORKS GRADE CAST IRON PIPE WITH MECHANICAL JOINTS.
- PROVIDE MINIMUM 1'-6" VERTICAL DISTANCE WHERE WATER AND SEWER LINES CROSS EACH OTHER. IF 1'-6" DISTANCE CANNOT BE MAINTAINED, THE SEWER MUST BE CONSTRUCTED OF WATER WORKS GRADE CAST IRON PIPE WITH MECHANICAL JOINTS WITHIN 10'-0" OF THE WATER LINE.
- NO PLASTIC WATER LINES SHALL BE USED.
- CONTRACTOR SHALL BE RESPONSIBLE FOR HIS RESPECTIVE WORK FOR REPAIRING AND PATCHING TO MATCH EXISTING SURFACES, SIDEWALKS, STREETS, FLOORS, WALLS, ROOFS, CEILING AND PAVEMENT.
- SHEETMETAL FABRICATION DRAWINGS ARE TO BE SUBMITTED TO THE ENGINEER. THE FABRICATION DRAWINGS SHALL INCLUDE ANY CHANGE NOTED AND APPROVED BY THE ARCHITECT/ENGINEER. THE FABRICATION OF DRAWINGS MUST BE COORDINATED WITH THE ELECTRICAL, STRUCTURAL, PLUMBING AND PIPING WORK INCLUDING CEILING HEIGHT AND DOORS (INCLUDING OVERHEAD DOORS) BEFORE SUBMITTAL. REWORK OF ELECTRICAL, PIPING, OR DUCTWORK BECAUSE OF CONFLICTS WILL BE CONSIDERED AS A PART OF THIS CONTRACT.
- MECHANICAL CONTRACTOR SHALL BE RESPONSIBLE FOR COORDINATING ALL OF HIS WORK TO BE INSTALLED WITH ANY AND ALL OTHER CONTRACTORS TO BE AFFECTED BY SUCH WORK, PRIOR TO ORDERING ANY OF THE EQUIPMENT. THIS SHALL INCLUDE BUT NOT BE LIMITED TO ELECTRICAL CHARACTERISTICS, CONNECTIONS REQUIRED, PHYSICAL SIZE, COLOR AND FIT. ALSO SEE SPECIFICATIONS.
- ALL EQUIPMENT SHALL BE OF, AND CONSIST OF, AT LEAST THE MINIMUM SIZES SELECTED, AND SHALL PERFORM TO OR SURPASS THE MINIMUM REQUIREMENTS, SCHEDULES, NOTED, AND SPECIFIED.
- ALL EXISTING EQUIPMENT, DUCTWORK, AND PIPING LOCATIONS AND SIZES OF ITEMS TO BE REMOVED OR REUSED SHALL BE FIELD VERIFIED BY THIS CONTRACTOR AT THE JOB SITE. THIS ALSO INCLUDES ITEMS THAT MAY CONFLICT WITH NEW WORK.

MECHANICAL ABBREVIATIONS

A AIR A.A. ANODIZED ALUMINUM A/C AIR CONDITIONING ADD ADDITION A.F.F. ABOVE FINISHED FLOOR AHU AIR HANDLING UNIT ALT ALTERNATE AMB AMBIENT A.P. ACID PROOF APPROX. APPROXIMATE ARV AIR RELIEF VENT AUTO AUTOMATIC AV ACID VENT AVG. AVERAGE AW ACID WASTE B.D.D. BACKDRAFT DAMPER B.F.W. BOILER FEED WATER B.L.C. BUILDING B.O. BLOW-OFF BSMT BASEMENT B.T. BATH TUB BTM BOTTOM BTUH BRITISH THERMAL UNIT CAP CAPACITY C.B. CATCH BASIN CEL CEILING CFM CUBIC FEET PER MINUTE C.I. CAST IRON CLG COOLING CLSK CLINICAL SERVICE SINK C.O. CLEANOUT COMP COMPRESSOR CONC CONCRETE COND CONDENSATE CONN CONNECTION CONST CONSTRUCTION CONT CONTINUOUS CONTR CONTRACTOR CONV CONVECTOR C.R. CONDENSER WATER RETURN CS CONDENSER WATER SUPPLY C.S. CABINET SINK C.U.H. CABINET UNIT HEATER C.W. COLD WATER C.W.R. CHILLED WATER RETURN C.W.S. CHILLED WATER SUPPLY d.b. DEGBELS D.B. DRY BULB (TEMPERATURE) DET DETAIL D.F. DRINKING FOUNTAIN DIA DIAMETER DIFF DIFFUSER DISCH DISCHARGE D.L. DOOR LOUVER DN DOWN D.S. DOWNSPOUT DWG DRAWING E.A.T. ENTERING AIR TEMPERATURE E.D. EQUIPMENT DRAIN E.D.R. EQUIVALENT SQ. FT. / DIRECT RADIATION EFF EFFICIENCY ELEV ELEVATION ENCL ENCLOSURE ENT ENTERING E.O.W. END OF MAIN DRIP EQUIP EQUIPMENT ESP EXTERNAL STATIC PRESSURE E.W.T. ENTERING WATER TEMPERATURE EXH EXHAUST EXIST EXISTING EXP EXPANSION EXT EXTERIOR F.A. FACE AREA F.C.U. FAN COIL UNIT F.D. FIRE DAMPER F.D. FLOOR DRAIN F.H. CAB FIRE HOSE CABINET FIN FINISH F.L. FIRE LINE FLEX FLEXIBLE FLR FLOOR F.O.G. FUEL OIL GAUGE F.O.R. FUEL OIL RETURN F.O.S. FUEL OIL SUPPLY PROP PROPELLER F.P.M. FEET PER MINUTE F&T FLOAT & THERMOSTATIC (TRAP) TURN TURN F.V. FACE VELOCITY G GAS GA GAUGE GALV GALVANIZED G.C. GENERAL CONTRACTOR GEN GENERATOR GPM GALLONS PER MINUTE G.T. GREASE TRAP H.B. HOSE BIBB HGT HEIGHT HORZ HORIZONTAL H.P. HORSE POWER H.P.R. HIGH PRESSURE STEAM RETURN H.P.S. HIGH PRESSURE STEAM SUPPLY HTG HEATING HVAC HEATING, VENTILATING, & AIR CONDITIONING HW HOT WATER (DOMESTIC) HWR HOT WATER RETURN (DOMESTIC) I.D. INSIDE DIAMETER INCH INCHES INCL INCLUDE INSUL INSULATION INT INTERIOR INV INVERT J.D. JANITORS DRAIN K.W. KILOWATT L.A.T. LEAVING AIR TEMPERATURE LAV LAVATORY LBS/HR POUNDS PER HOUR L.C. LAVATORY IN CABINET L.F. LINEAR FEET LOC LOCATION L.P.R. LOW PRESSURE STEAM RETURN L.P.S. LOW PRESSURE STEAM SUPPLY LVG LEAVING L.W.T. LEAVING WATER TEMPERATURE MAX MAXIMUM MBH THOUSANDS OF BTU/HR M.C.C. MOTOR CONTROL CENTER MECH MECHANICAL M.F. MIXING FAUCET MFR MANUFACTURER M.H. MANHOLE MIN MINIMUM MISC MISCELLANEOUS M.P.R. MEDIUM PRESSURE STEAM RETURN M.P.S. MEDIUM PRESSURE STEAM SUPPLY MTD MOUNTED N.C. NORMALLY CLOSED NEG NEGATIVE N.I.C. NOT IN CONTRACT N.O. NORMALLY OPEN N.T.S. NOT TO SCALE Ø PHASE O.A. OUTSIDE AIR O.D. OUTSIDE DIAMETER O.F.D. OVERFLOW ROOF DRAIN OPNG OPENING OPP OPPOSITE ORIG ORIGINAL P.D. PRESSURE DROP P.E. PNEUMATIC ELECTRIC P.I.V. POST INDICATOR VALVE PREFAB PREFABRICATED PRESS PRESSURE PROP PROPELLER P.R.V. PRESSURE REDUCING VALVE P.S.I.A. POUNDS PER SQUARE INCH (ABSOLUTE) P.S.I.G. POUNDS PER SQUARE INCH (GAUGE) P.U.H. PROPELLER UNIT HEATER R HOT WATER RETURN (HVAC) R.A. RETURN AIR RAD RADIATION R.D. ROOF DRAIN REC RECEIVER RECIR RECIRCULATING RECT RECTANGULAR REG REGISTER REINF REINFORCED REL RELIEF RET RETURN REQD REQUIRED R.H. RODDING HOLE R.H. RELATIVE HUMIDITY RM ROOM R.P.M. REVOLUTIONS PER MINUTE S HOT WATER SUPPLY (HVAC) S.A. SOUND ATTENUATOR SAN SANITARY S.C. SILL COCK SCW SOFT COLD WATER S.D. SHOWER DRAIN SECT SECTION S.H. SHOWER HEAD SHT SHEET SK SINK S.P. STATIC PRESSURE SPEC SPECIFICATIONS SPR SPRINKLER SQ SQUARE S.S. STAINLESS STEEL ST STORM STAT THERMOSTAT STD STANDARD STM STEAM STR STRUCTURAL SUP SUPPLY SUSP SUSPENDED T.D. TEMPERATURE DIFFERENCE TEMP TEMPERATURE TOT TOTAL T.S.P. TOTAL STATIC PRESSURE T.W. TEMPERED WATER TYP TYPICAL U.C. UNDERCUT U.H. UNIT HEATER UR URINAL U.V. UNIT VENTILATOR V VENT VA VALVE VAC VACUUM V.D. VOLUME DAMPER VEL VELOCITY VENT VENTILATOR V.T. VITRIFIED TILE V.T.R. VENT THRU ROOF W WASTE W/ WITH W.B. WET BULB (TEMPERATURE) W.C. WATER CLOS W.F.R. WALL FIN RADIATION W/O WITHOUT W.P. WEATHERPROOF WT WEIGHT WTR WATER

                     SHEETMETAL SYMBOLS

	SUPPLY DUCT (SECTION)		RETURN, EXHAUST, RELIEF OR INTAKE DUCT (SECTION)
	RECTANGULAR DUCT (1ST FIG. SIDE SHOWN; 2ND FIG. SIDE NOT SHOWN)		ROUND DUCT (FIG. INDICATED DIAMETER)
	FLAT OVAL DUCT (1ST FIG. SIDE SHOWN; 2ND FIG. SIDE NOT SHOWN)		FLEXIBLE DUCT
	CHANGE IN ELEVATION OF DUCT (R) RISE (D) DROP ARROW INDICATES DIRECTION		TURNING VANES
	AIR DIVERTER (EXTRACTOR)		MANUAL SPLITTER DAMPER
	VOLUME DAMPER		MOTORIZED DAMPER
	BACKDRAFT DAMPER		FIRE DAMPER (FD) SMOKE DAMPER (SD) RADIATION DAMPER (RD)
	DUCT SIZE INSIDE RECTANGLE INDICATES DUCT TO BE DOUBLE WALL WITH SOLID INNER LINER		FLEXIBLE CONNECTION
	SUPPLY AIR DIRECTION		EXHAUST OR RETURN INLET (NOMINAL SIZE, TYPE, & AIR QUANTITY IN CFM INDICATED)
	RETURN, EXHAUST, OR RELIEF AIR DIRECTION		ALL UNITS LOCATED IN OR NEAR CEILING, UNLESS DIMENSION SHOWN INDICATING (HEIGHT A.F.F.)
	SUPPLY OUTLET (NOMINAL DIAMETER, TYPE, & AIR QUANTITY INDICATED)		SQUARE DIFFUSER (NECK SIZE, TYPE & AIR QUANTITY IN CFM INDICATED)
	ROUND DIFFUSER (NECK DIAMETER, TYPE, & AIR QUANTITY IN CFM INDICATED)		ALL DIFFUSERS EXCEPT LINEAR TYPE ARE 4-WAY UNLESS OTHERWISE INDICATED
	LINEAR DIFFUSER, LINEAR GRILLE (TYPE & AIR QUANTITY INDICATED)		POWER OR GRAVITY ROOF VENTILATOR
	(T) THERMOSTAT, W/(E) ELEC. STAT., W/ (N) NIGHT STAT., W/ (G) GUARDED S.T., (H) HUMIDISTAT		DOOR GRILLE (FREE AREA REQUIRED & AIR QUANTITY IN CFM INDICATED)
	DOOR, UNDERCUT (SIZE & AIR QUANTITY IN CFM INDICATED)		

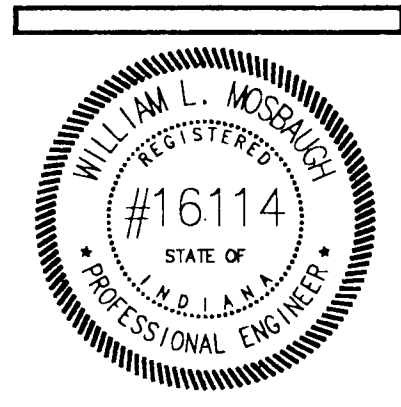

CERTIFIED

THE ODLE MCGUIRE & SHOOK CORPORATION
ARCHITECTURE • ENGINEERING • LANDSCAPE ARCHITECTURE • INTERIOR DESIGN
6765 NORTH STATE ROAD 37, POST OFFICE BOX 2149, BLOOMINGTON, INDIANA 47402, 812/676-2020
8755 ALLISON POINTE TRAIL, POST OFFICE BOX 30428, INDIANAPOLIS, INDIANA 46236, 317/692-6000


REVISIONS

© Copyright 1984 by THE ODLE MCGUIRE & SHOOK CORPORATION. Copyright includes architectural work, building design, plans or drawings, and specifications. Reproduction of work in the small form as well as the enlargement and compilation of notes and materials in the design. Reproduction without written permission is prohibited.

MICHIGAN CITY SPORTS COMPLEX
AMES FIELD
MICHIGAN CITY, INDIANA

PROJECT NO. 93052
DATE: MAY 31, 1994
drawn by: PJD, KCS
checked by: WLM

MP101
MECHANICAL AND PLUMBING SYMBOLS AND ABBREVIATIONS

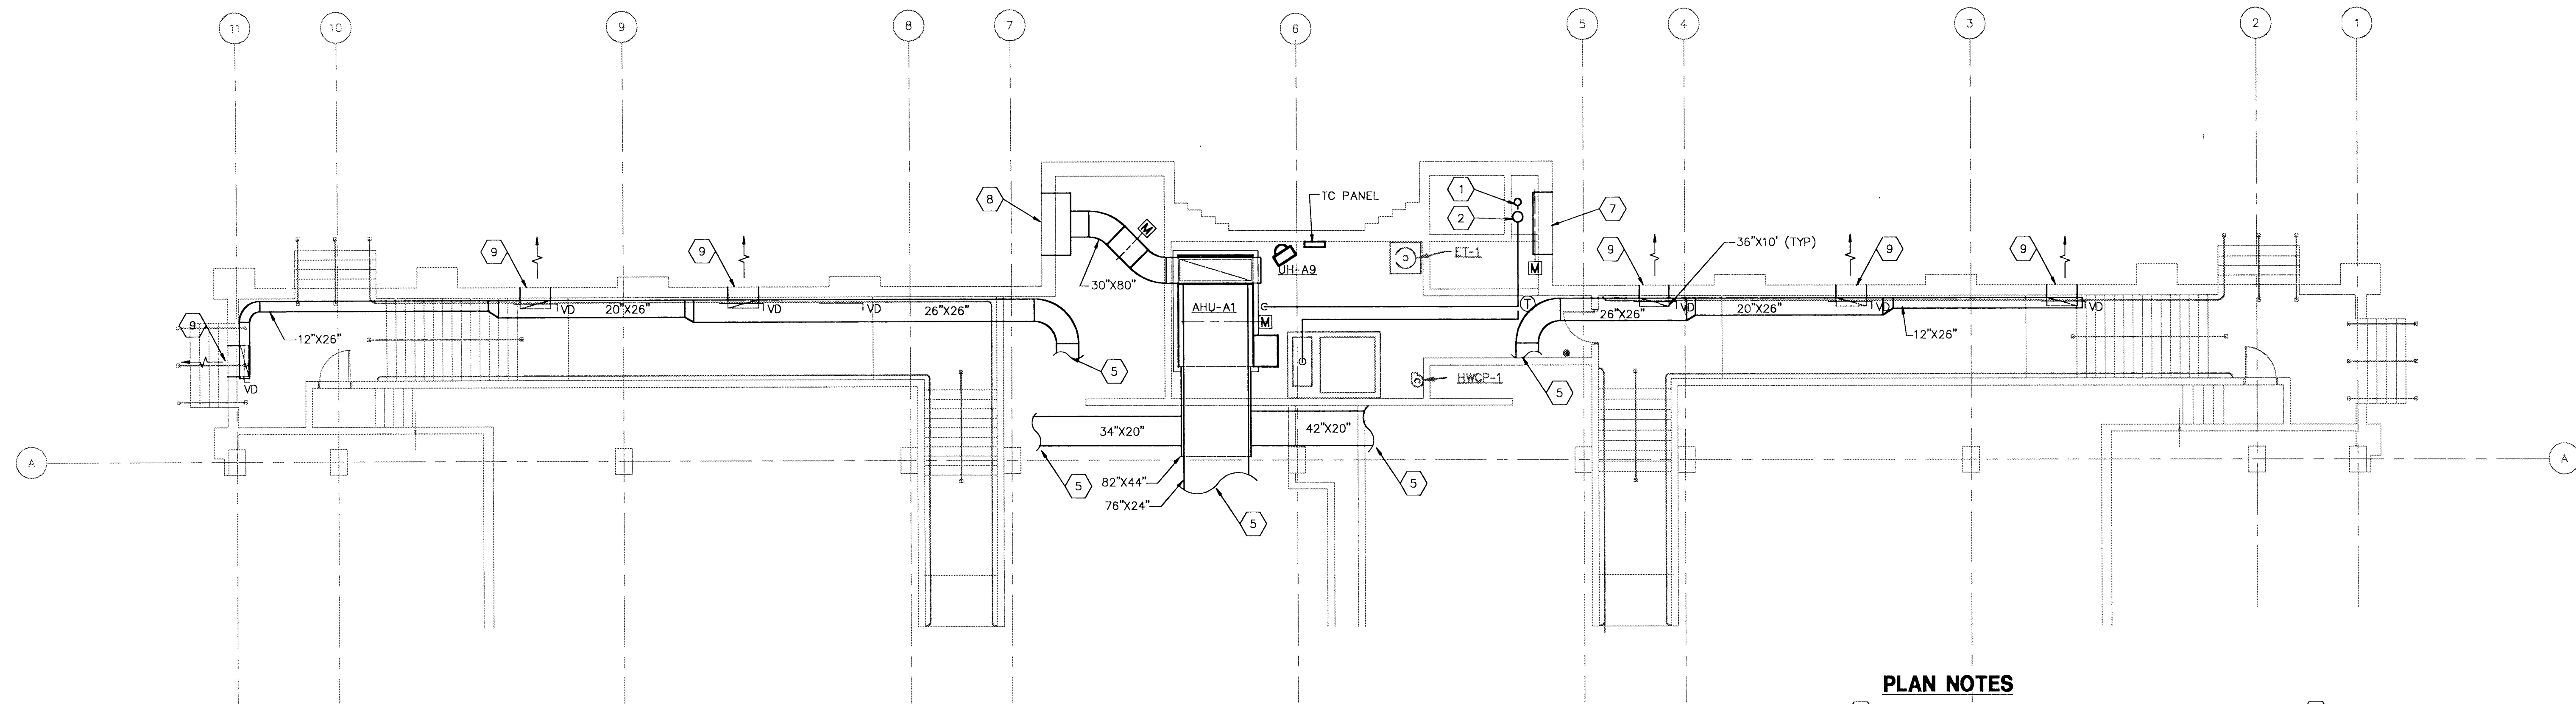

FOOTBALL STADIUM INTERIOR RAMP HVAC PLAN


SCALE 1/8" = 1'-0"

GENERAL NOTES

- MECHANICAL EQUIPMENT TO BE LOCATED AS TIGHT TO STRUCTURE AS POSSIBLE.
- MANUAL VOLUME DAMPERS TO BE PROVIDED FOR EACH GRILLE AND DIFFUSER TAKE-OFF.
- FIRE DAMPERS TO BE PROVIDED AT ALL LOCATIONS WHERE DUCTWORK PENETRATES A FIRE BARRIER.
- GRILLES & DIFFUSERS LOCATED IN AREAS WITHOUT CEILINGS TO BE LOCATED 12'-0" AFF. IF THIS IS NOT POSSIBLE BECAUSE OF STRUCTURE, INSTALL AS TIGHT TO BOTTOM OF STRUCTURE AS POSSIBLE.

PLAN NOTES

- 8" WATER HEATER FLUE TO RUN TO CHASE AND THROUGH ROOF. REFER TO SHEET M202 FOR CONTINUATION.
- 12" GAS FLUE TO RUN TO CHASE AND THROUGH ROOF. REFER TO SHEET M202 FOR CONTINUATION.
- INSTALL GRILLES 6" AFF., TYPE 'G', TYPICAL OF 2.
- INSTALL GRILLES 6" BELOW FINISHED CEILING, TYPE 'G', TYPICAL OF 2.
- FOR CONTINUATION OF DUCT, REFER TO FOOTBALL STADIUM FLOOR PLAN ON THIS SHEET.
- FOR CONTINUATION OF DUCT REFER TO FOOTBALL STADIUM INTERIOR RAMP PLAN ON THIS SHEET.
- COMBUSTION AIR LOUVER TO CONSIST OF FOUR 12" DEEP SEPERATE PLENUMS, TWO 2.5 SF. OF LOUVER FREE AREA ONE HIGH & ONE LOW WITH A MOTOR OPERATED DAMPER ON EACH PLENUM TIED TO THE AIR HANDLER, TWO 1.2 SF. OF LOUVER FREE AREA ONE HIGH & ONE WITH A MOTOR OPERATED DAMPER ON EACH PLENUM TIED TO THE DOMESTIC WATER HEATER. REFER TO ARCH. PLANS FOR EXACT SIZE AND LOCATION OF LOUVER.
- OUTDOOR AIR INTAKE LOUVER, PROVIDE 18" DEEP SHEETMETAL PLENUM, ATTACH DUCTWORK AS SHOWN. REFER TO ARCH. PLANS FOR EXACT SIZE AND LOCATION OF LOUVER.
- EXHAUST AIR LOUVER, PROVIDE CONNECTION TO EXHAUST DUCTWORK AS SHOWN, REFER TO ARCH. PLANS FOR EXACT SIZE AND LOCATION OF LOUVER.
- ELEVATOR EQUIPMENT ROOM EXHAUST LOUVER, PROVIDE 18" DEEP SHEETMETAL PLENUM, ATTACH DUCTWORK AS SHOWN. REFER TO ARCH. PLANS FOR EXACT SIZE AND LOCATION OF LOUVER.
- DUCTWORK TO RUN UNDER INTERIOR RAMP AS TIGHT TO THE BOTTOM OF THE RAMP STRUCTURE AS POSSIBLE.

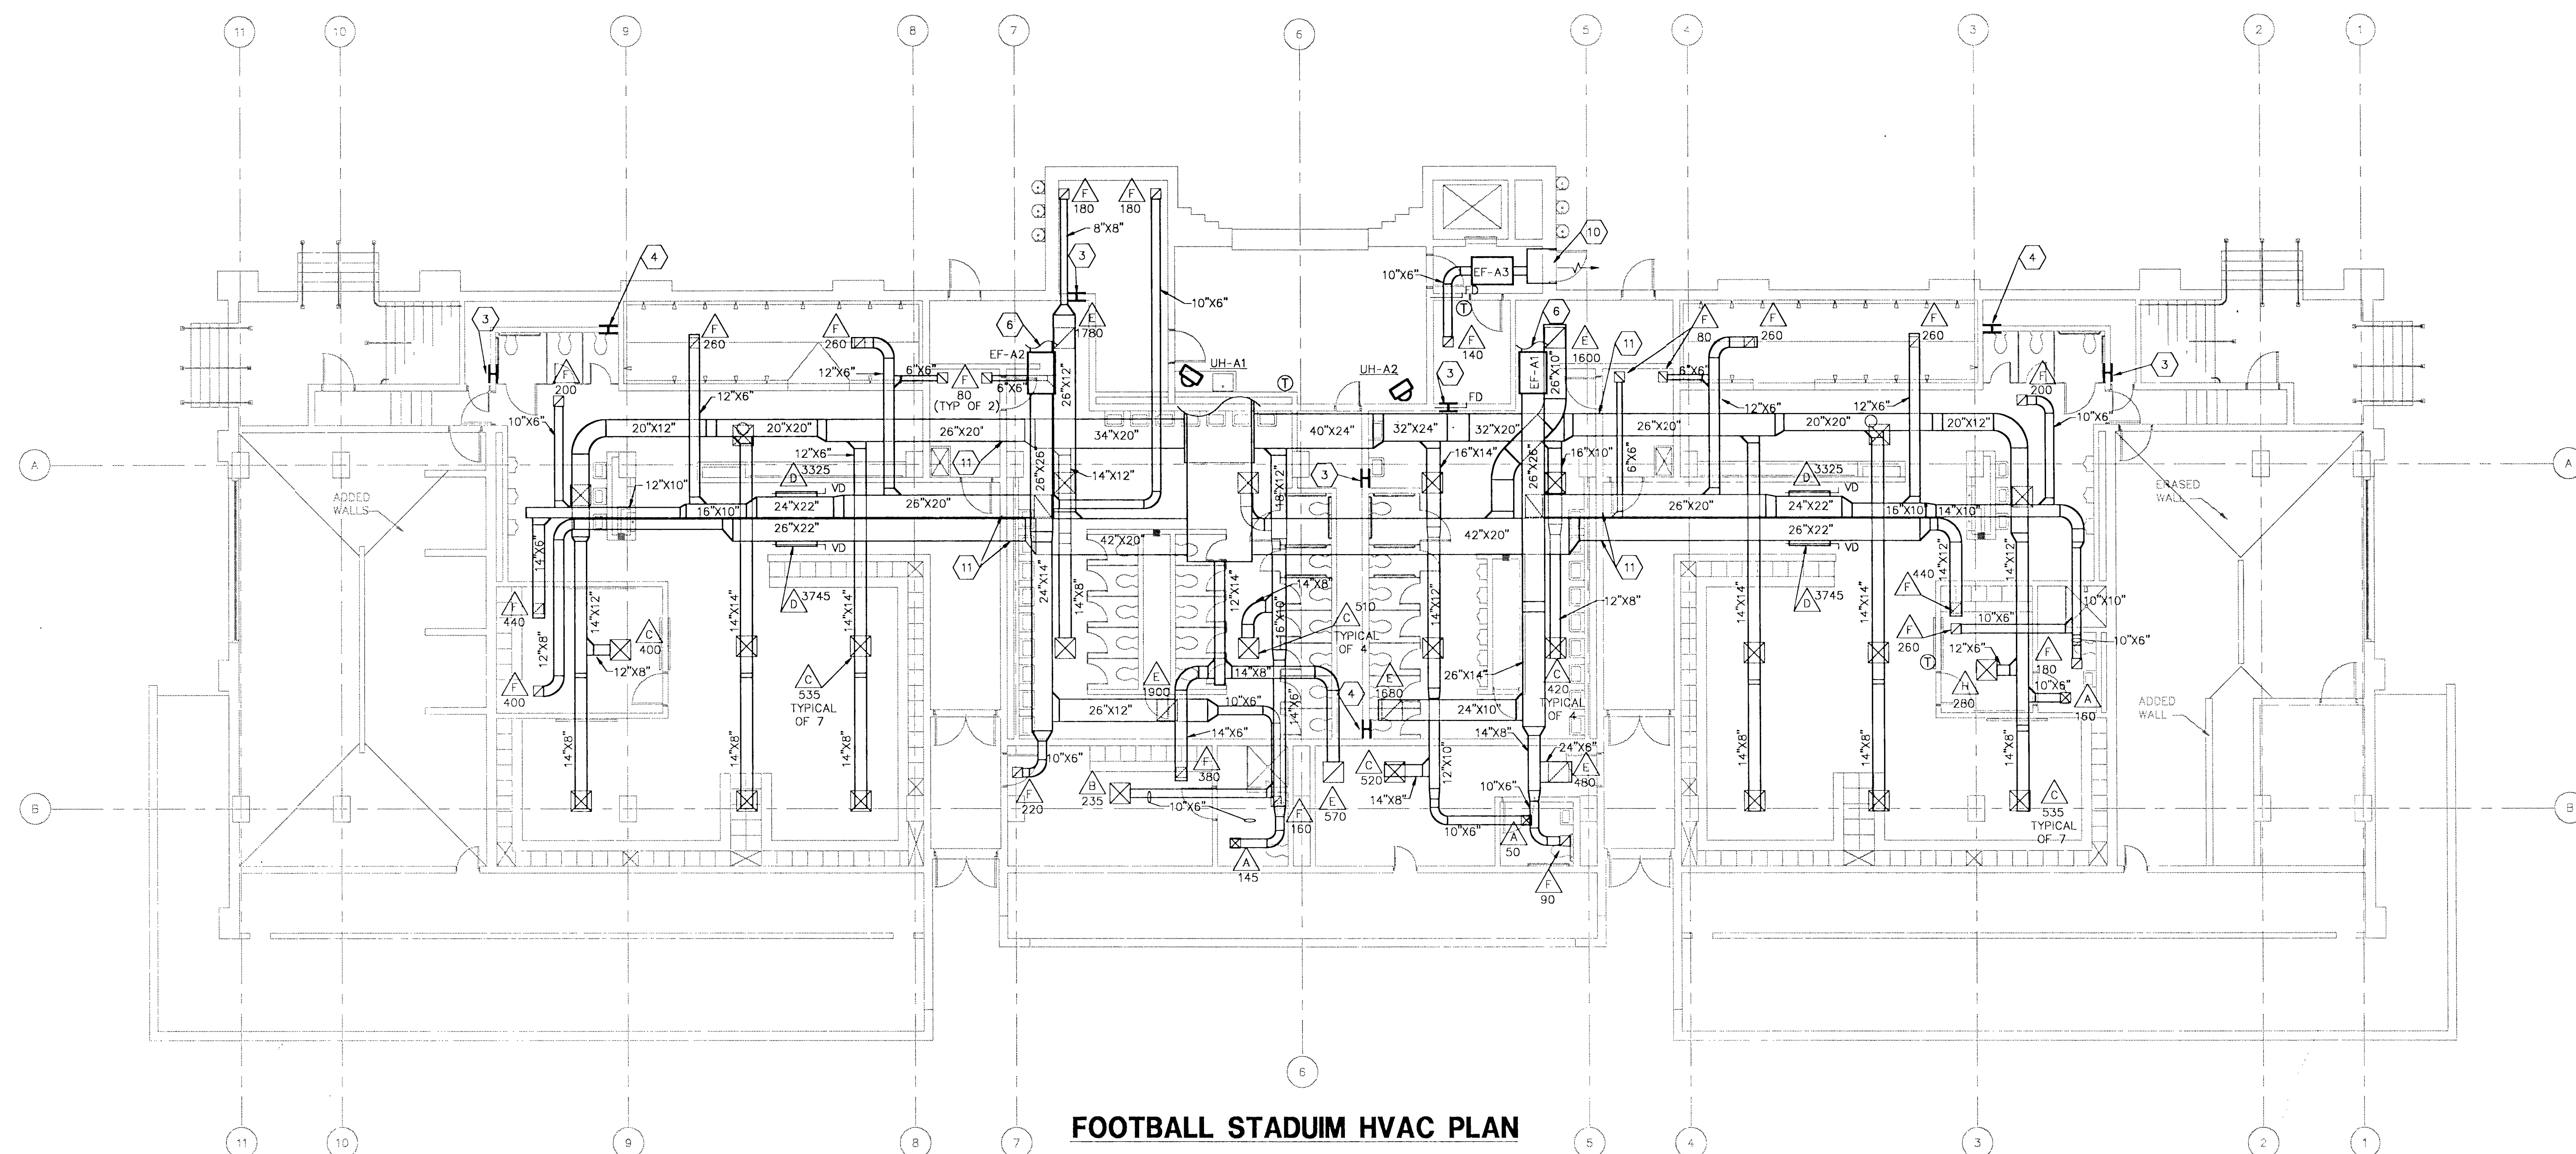

FOOTBALL STADIUM HVAC PLAN

SCALE 1/8" = 1'-0"



CERTIFIED

THE ODLE MCGUIRE & SHOOK CORPORATION
ARCHITECTURE • ENGINEERING • LANDSCAPE ARCHITECTURE • INTERIOR DESIGN
6705 NORTH STATE ROAD 37, POST OFFICE BOX 2418, BLOOMINGTON, INDIANA 47403, 812/836-2000
8075 AULISON POINTE TRAIL, POST OFFICE BOX 50428, INDIANAPOLIS, INDIANA 46250, 317/842-0000

REVISIONS


© Copyright 1994 by THE ODLE MCGUIRE & SHOOK CORPORATION. Copyright includes architectural work, building design, plans or drawings, and specifications. Architectural work is the overall form as well as the arrangement and construction of space and elements in the design. Reproduction without written permission is prohibited.

MICHIGAN CITY SPORTS COMPLEX
AMES FIELD
MICHIGAN CITY, INDIANA

PROJECT NO. 93052
DATE: MAY 31, 1994
Drawn by: KCS
checked by: WLM

M201

GRANDSTAND
HVAC PLAN

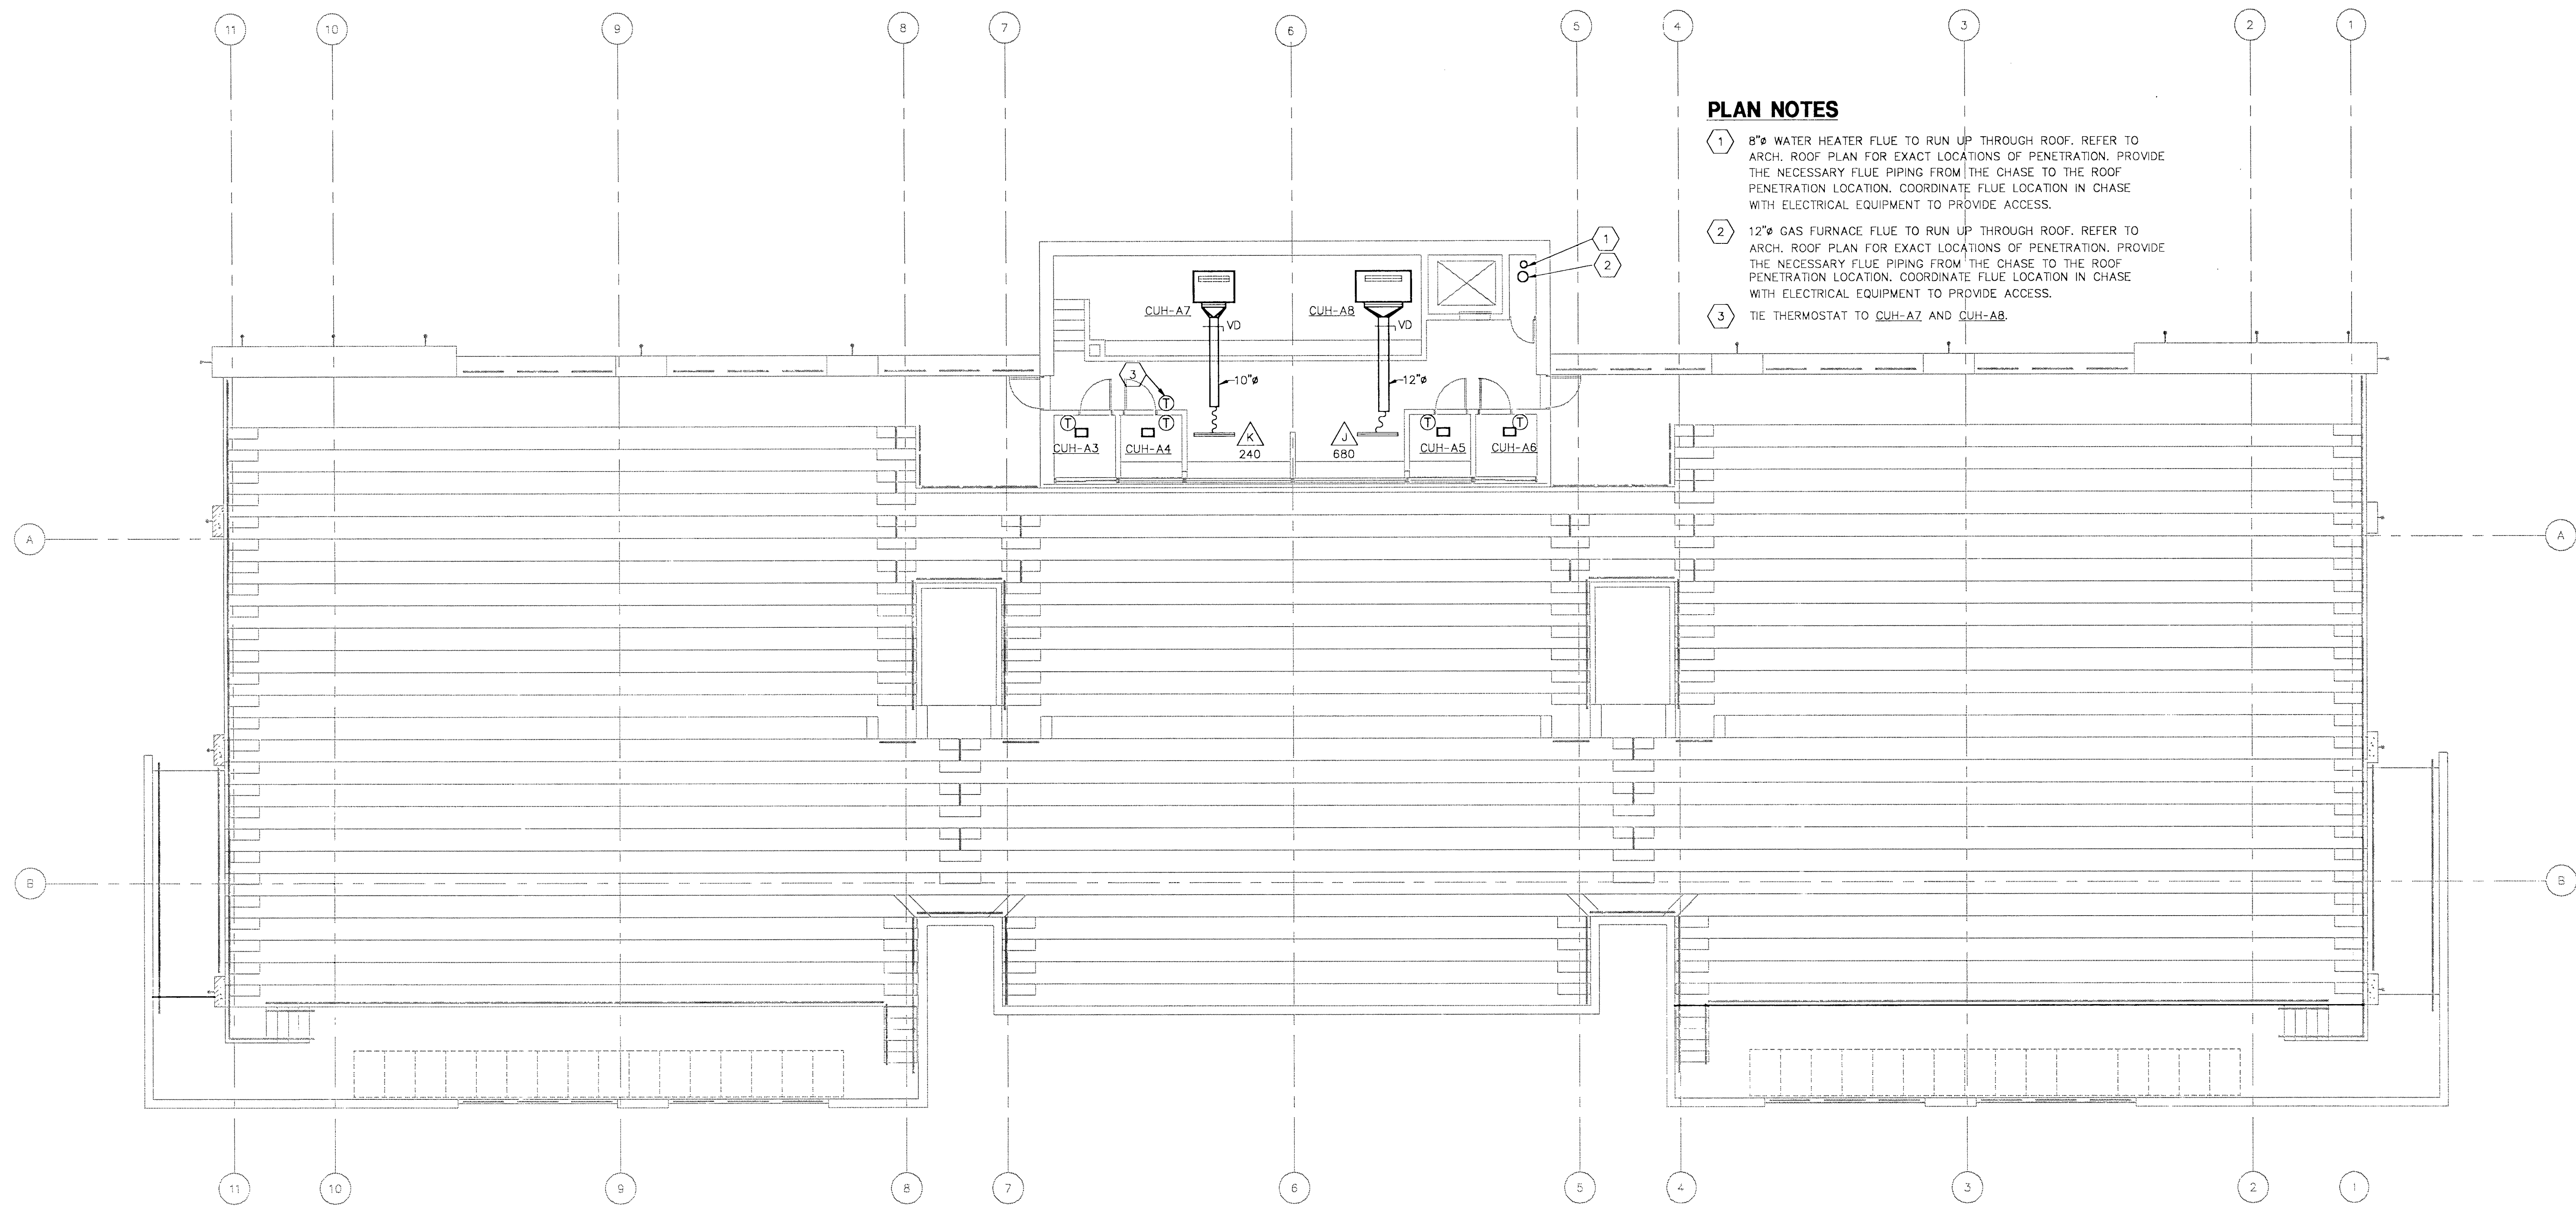


PRESS BOX HVAC PLAN
SCALE 1/8" = 1'-0"

PLAN NOTES

- 1 18"x18" EXHAUST DUCT UP TO REF-B1. PROVIDE BACKDRAFT DAMPER AND BIRDSCREEN WITH EXHAUST FAN.
- 2 12"x6" EXHAUST DUCT DOWN TO 6" AFF. INSTALL 10"x6" EXHAUST GRILLE TYPE 'Y' 8" AFF. 100 CFM.
- 3 PROVIDE TWO 18" DEEP SHEET METAL PLENUMS AND MOTOR OPERATED DAMPERS CONNECTED TO INTAKE/COMBUSTION LOUVER. TIE TO REF-B1 AND UNIT HEATERS. REFER TO ARCH. PLANS FOR EXACT DIMENSION OF LOUVER.
- 4 TRANSFER AIR GRILLE. LOCATE TOP OF GRILLE 6" BELOW FINISHED CEILING TYP. OF 2.
- 5 PROVIDE TWO 18" DEEP SHEET METAL PLENUMS AND MOTOR OPERATED DAMPERS CONNECTED TO INTAKE/COMBUSTION LOUVER. TIE TO UNIT HEATER UH-B3. REFER TO ARCH. PLANS FOR EXACT DIMENSION OF LOUVER.
- 6 4" FLUE FROM WATER HEATER TO RUN UP THRU ROOF. REFER TO ARCH. ROOF PLAN FOR EXACT LOCATION OF PENETRATION. PROVIDE ALL FLUE PIPING NECESSARY FROM THE WATER HEATER TO ROOF PENETRATION LOCATION.
- 7 PROVIDE 18" DEEP SHEET METAL PLENUM TWO 12"x4" DUCTS TO STUB INTO ROOM AND TWO MOTOR OPERATED DAMPERS CONNECTED TO INTAKE/COMBUSTION LOUVER. TIE TO DOMESTIC WATER HEATER. REFER TO ARCH. PLANS FOR EXACT DIMENSION OF LOUVER.

GENERAL NOTES

- 1 ALL THERMOSTATS TO HAVE NON-ADJUSTABLE TAMPER RESISTANT COVERS.
- 2 EXHAUST FAN TO HAVE A MANUAL ON/OFF SWITCH LOCATED IN JANITOR/MECH. RM.

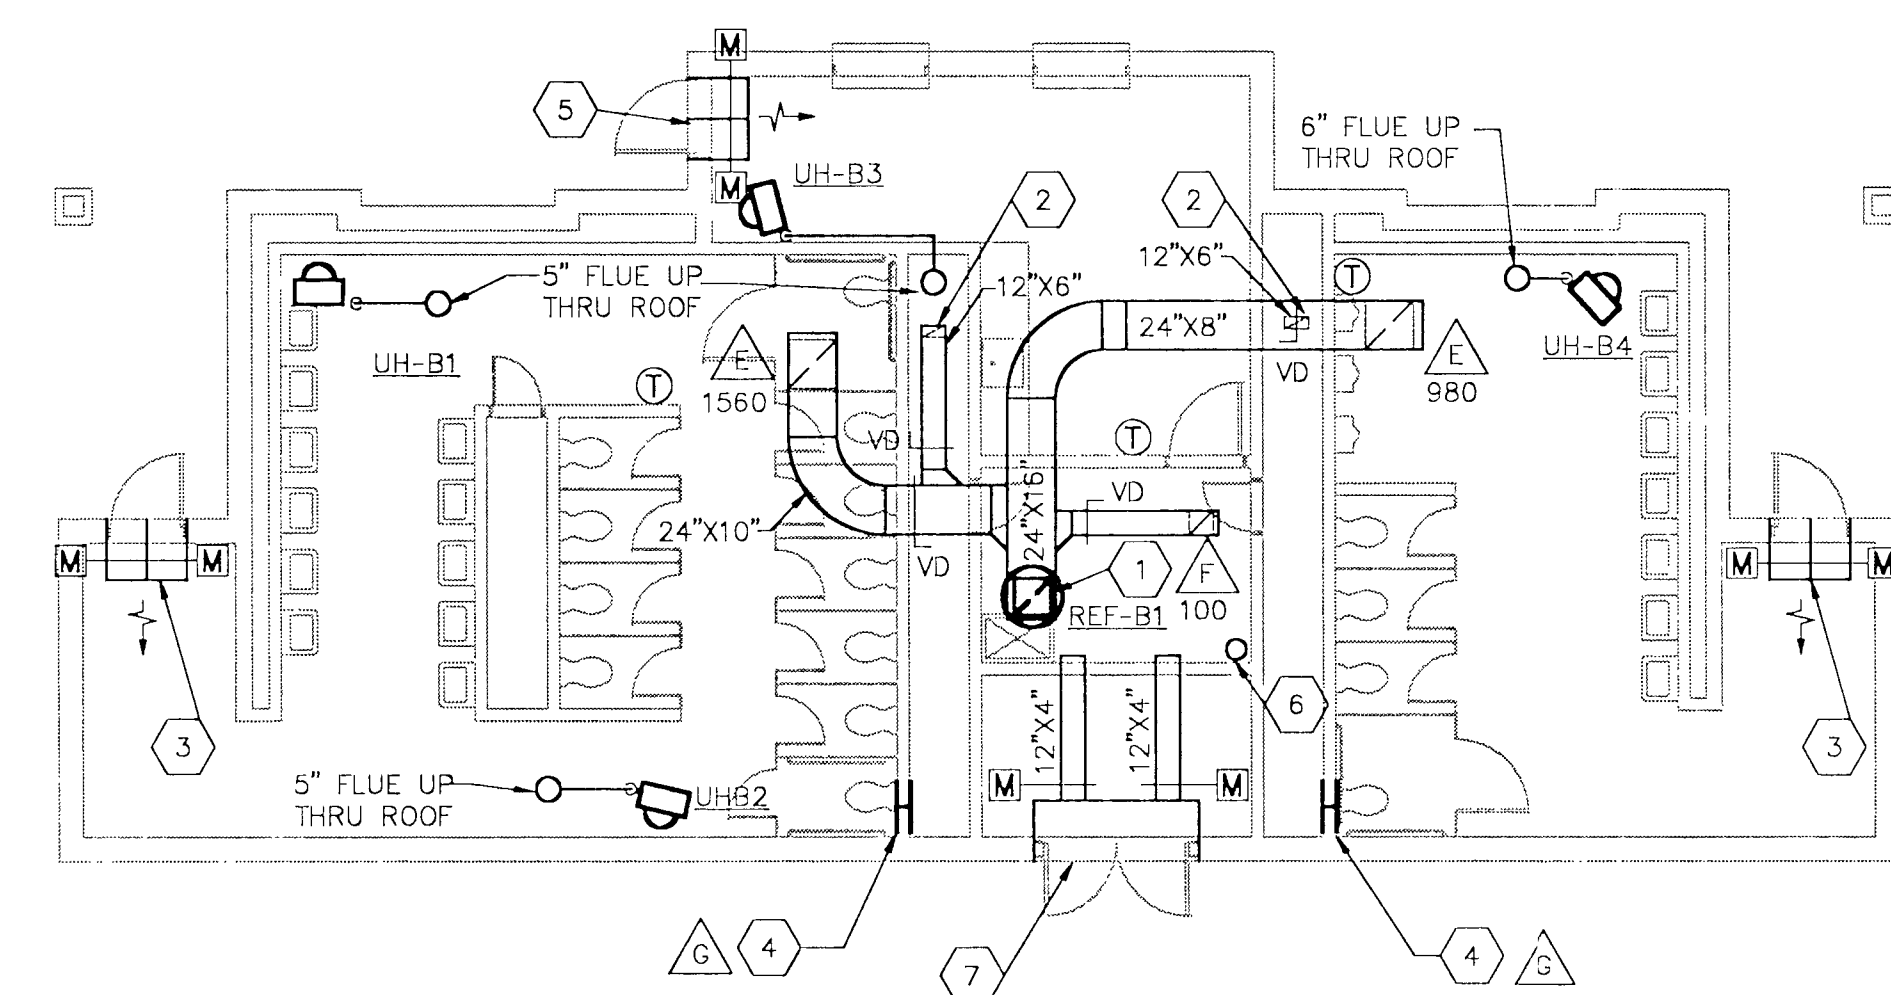

VISITOR TOILET & CONCESSION HVAC PLAN
SCALE 1/8" = 1'-0"



CERTIFIED
William J. Mahoney

THE ODLE MCGUIRE & SHOOK CORPORATION
ARCHITECTURE • ENGINEERING • LANDSCAPE ARCHITECTURE • INTERIOR DESIGN
6276 NORTH STATE ROAD 37, POST OFFICE BOX 2148, BLOOMINGTON, INDIANA 47402, 812/876-2020
8275 ALLISON POINTE TRAIL, POST OFFICE BOX 50428, INDIANAPOLIS, INDIANA 46250, 317/842-0000

REVISIONS

© Copyright 1994 by THE ODLE MCGUIRE & SHOOK CORPORATION. Copyright includes architectural work, building design, plans or drawings, and specifications. Architectural work is the owner's form as well as the owner's text and compilation of space and elements in the design. Reproduction without written permission is prohibited.

MICHIGAN CITY SPORTS COMPLEX
AMES FIELD
MICHIGAN CITY, INDIANA

PROJECT NO. 93052
DATE: MAY 31, 1994
drawn by: KCS
checked by: WLM

M202
VISITOR TOILET/
CONCESSION & PRESS
BOX HVAC PLAN

NO.	LOCATION	STYLE		FAN CFM	S.P.	INPUT MBH	OUTPUT MBH	*F RISE	WATTS	UNIT AMPS	MOTOR				MOUNTING ARRANGEMENT	NOTES	MANUFACTURER
		UH	CUH								HP	RPM	VOLTS	PHASE			
A1	A112	xx		400	-	-	11.2	26	3300	15.9	1/125	1550	277	1	SIDEWALL	3	TRANE UHEC-031
A2	A112	xx		400	-	-	11.2	26	3300	15.9	1/125	1550	277	1	SIDEWALL	3	TRANE UHEC-031
A3	A126		xx	65	-	-	6.8	92	2000	8.4	-	-	208	1	CEILING RECESSED		Q-MARK CWH-202-1
A4	A127		xx	65	-	-	6.8	92	2000	8.4	-	-	208	1	CEILING RECESSED		Q-MARK CWH-202-1
A5	A124		xx	65	-	-	6.8	92	2000	8.4	-	-	208	1	CEILING RECESSED		Q-MARK CWH-202-1
A6	A125		xx	65	-	-	6.8	92	2000	8.4	-	-	208	1	CEILING RECESSED		Q-MARK CWH-202-1
A7	A123		xx	680	0.15	-	51.2	70	15000	6.8	1/12	710	115	1	HORIZONTAL RECESSED	2	TRANE E366E008
A8	A123		xx	680	0.15	-	51.2	70	5620	18	1/12	710	115	1	HORIZONTAL RECESSED	2	TRANE E366E008
A9	MEZZANNE	xx		1800	-	-	85.3	44	25000	69.5	1/12	1550	480	2	SIDEWALL	3	TRANE UHEC-253
B1	B102	xx		1480	-	100	80	50	-	5.8	1/20	1050	115	1	SIDEWALL	1	TRANE GHND-010
B2	B102	xx		1480	-	100	80	50	-	5.8	1/20	1050	115	1	SIDEWALL	1	TRAND GHND-010
B3	B101	xx		1050	-	60	48	42	-	4.5	1/30	1050	115	1	SIDEWALL	1	TRANE GHND-006
B4	B105	xx		2200	-	150	120	50	-	7.2	1/4	1140	115	1	SIDEWALL	1	TRAND GHND-015

NOTES:

1. FLUE VENT FAN MOTORS USED ON THIS UNIT IS 115/60V, 1/20HP, 1.5.
2. 480 V, 3 PHASE, 3 WIRE ELECTRIC COIL.
3. UNIT TO BE TOTAL ELECTRIC.

FAN NO.	AREA SERVED	CFM	EXT. S.P. V.C.	FAN MOTOR HP	FAN RPM	DRIVE	SOUND LEVEL SONES	FAN OPER. *	NOTES	MANUFACTURER
A1	VISITOR SIDE	6815	1.0	5	1215	BELT	23	M	1, 3	GREENHECK BSO-240HP-50
A2	HOME SIDE	7025	1.0	5	1220	BELT	23	M	1, 3	GREENHECK BSO-240HP-50
A3	A114	140	0.5	1/4	1390	BELT	10	T	1, 4	GREENHECK BSO-70-4
B1	B101, B102, B105	2640	1875	3/4	1020	BELT	12	M	1,2,4	GREENHECK GB180-7

* C - CONTINUOUS DAY AND NIGHT OPERATION.
 H - MANUALLY STARTED OPERATION *AS-REQUIRED*.
 N - ON NIGHT SET-BACK, CONTINUOUS DAYTIME OPERATION.
 T - CONTROL WITH ROOM TEMPERATURE SENSOR.

NOTES:

1. BACKDRAFT DAMPER
2. BIRDSGREEN
3. 480V, 3 PH
4. 120V, 1 PH

TYPE △	STYLE	DESCRIPTION	MAX. IN.	NOTES	MANUFACTURER / MODEL
A	DIFFUSER	12"X12" MODULE, 12"X12" FACE, 6"Ø	25	1	TITUS TMS
B	DIFFUSER	24"X24" MODULE, 24"X24" FACE, 8"Ø	25	1	TITUS TMS
C	DIFFUSER	24"X24" MODULE, 24"X24" FACE, 12"Ø	25	1	TITUS TMS
D	GRILLE	48"X18" FACE, 1/2" SPACING, 38" DEF.	25	1	TITUS 33RL
E	GRILLE	24"X24" EGGRATE, 1/2"X1/2"X1/2" ALUM. GRID	25	1	TITUS 50F
F	GRILLE	12"X12" EGGRATE, 1/2"X1/2"X1/2" ALUM. GRID	25	1	TITUS 50F
G	GRILLE	14"X8" FACE, 3/4" SPACING, 35" DEF.	25	1	TITUS 350RL
H	DIFFUSER	24"X24" MODULE, 24"X24" FACE, 10"Ø	25	1	TITUS TMS
I	GRILLE	10"X6" FACE, 3/4" SPACING, 35" DEF.	25	1	TITUS 350RL
J	DIFFUSER	1 1/2" SLOT, 4 SLOTS, 48" LONG, 12"Ø OVAL	30	1	TITUS TBD-80
K	DIFFUSER	1 1/2" SLOT, 4 SLOTS, 48" LONG, 8"Ø	25	1	TITUS TBD-80

NOTES: 1. PROVIDE A MANUAL VOLUME DAMPER FOR EACH GRILLE & DIFFUSER AT THE TAKE-OFF.

MAKE-UP AIR HANDLING UNIT																	
UNIT NO.	MODEL NO.	TYPE OF UNIT	CFM		TOTAL S.P.	INTERN. S.P.	FAN DATA				HEATING DATA				UNIT NO.	NOTES	MANUFACTURER
			TOTAL	D.A.			RPM	HP	VOLT	PH	OUTPUT MBH	INPUT MBH	RISE °F	FUEL			
AHU-A1	SDX-150GMFH	INDIRECT FIRED INDOOR	13000	13000	1.41	0.41	802	10	480	3	1404	1875	100	GAS	AHU-A1	1	JACKSON & CHURCH

NOTES: 1. 2" THROW-AWAY FLAT FILTERS AND FILTER SECTION.

**CERTIFIED**

THE ODLE MCGUIRE & SHOOK CORPORATION

ARCHITECTURE • ENGINEERING • LANDSCAPE ARCHITECTURE • INTERIOR DESIGN

6785 NORTH STATE ROAD 37, POST OFFICE BOX 2148, BLOOMINGTON, INDIANA 47402	612/876-2020
18275 ALLISON PONTE TRAIL, POST OFFICE BOX 50424, INDIANAPOLIS, INDIANA 46250	317/842-0000

REVISION


© Copyright 1984 by THE OOLE MOLLER & SCHOON CORPORATION. Copyright includes architectural work, building design, plans or drawings, and specifications. Architectural work is the overall form as well as the arrangement and composition of spaces and elements in the design. Reproduction without written permission is prohibited.

AMES FIELD
MICHIGAN CITY, INDIANA
MICHIGAN CITY SPORTS COMPLEX

PROJECT NO. 83052
DATE MAY 31, 1984
drawn by: KCS
checked by: WLM


M301

HYAC 8 SCHEDULES

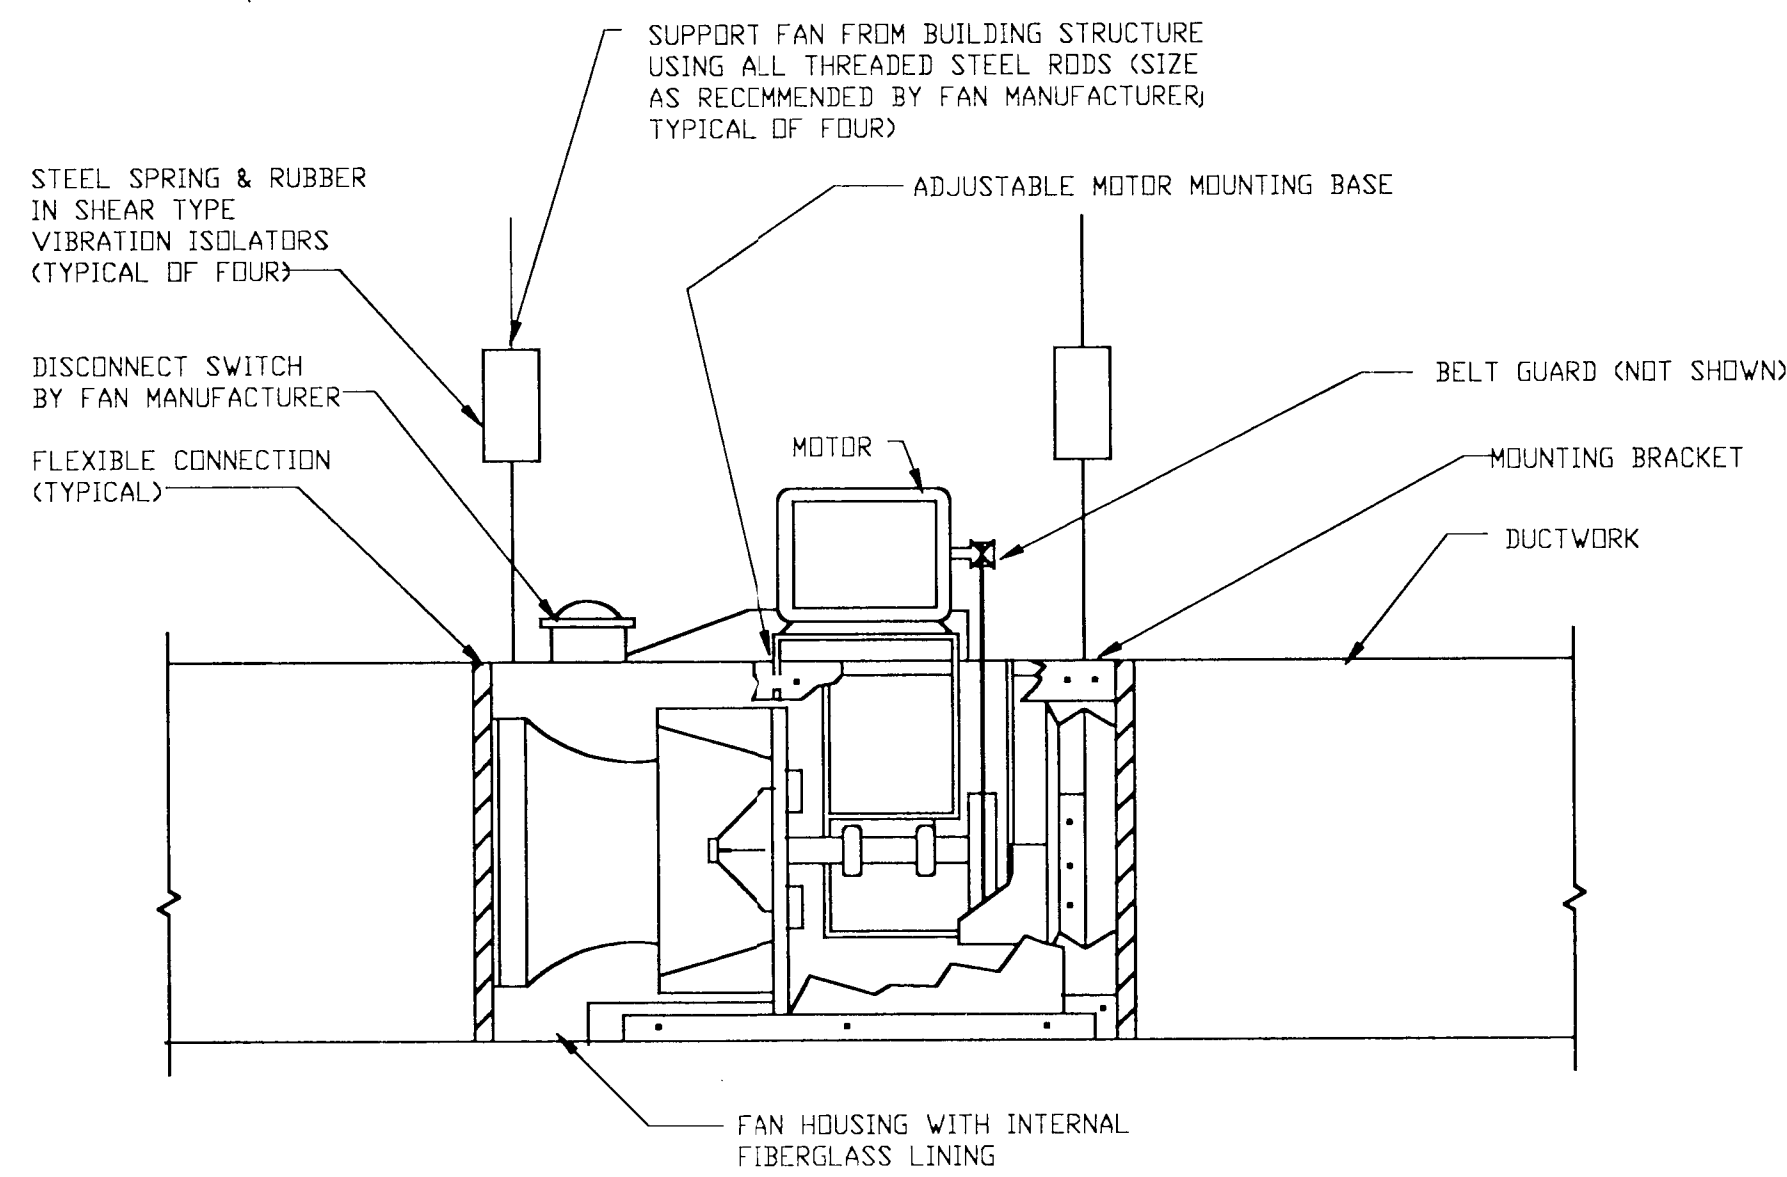


CENTRIFUGAL IN-LINE FAN DETAIL

NO SCALE

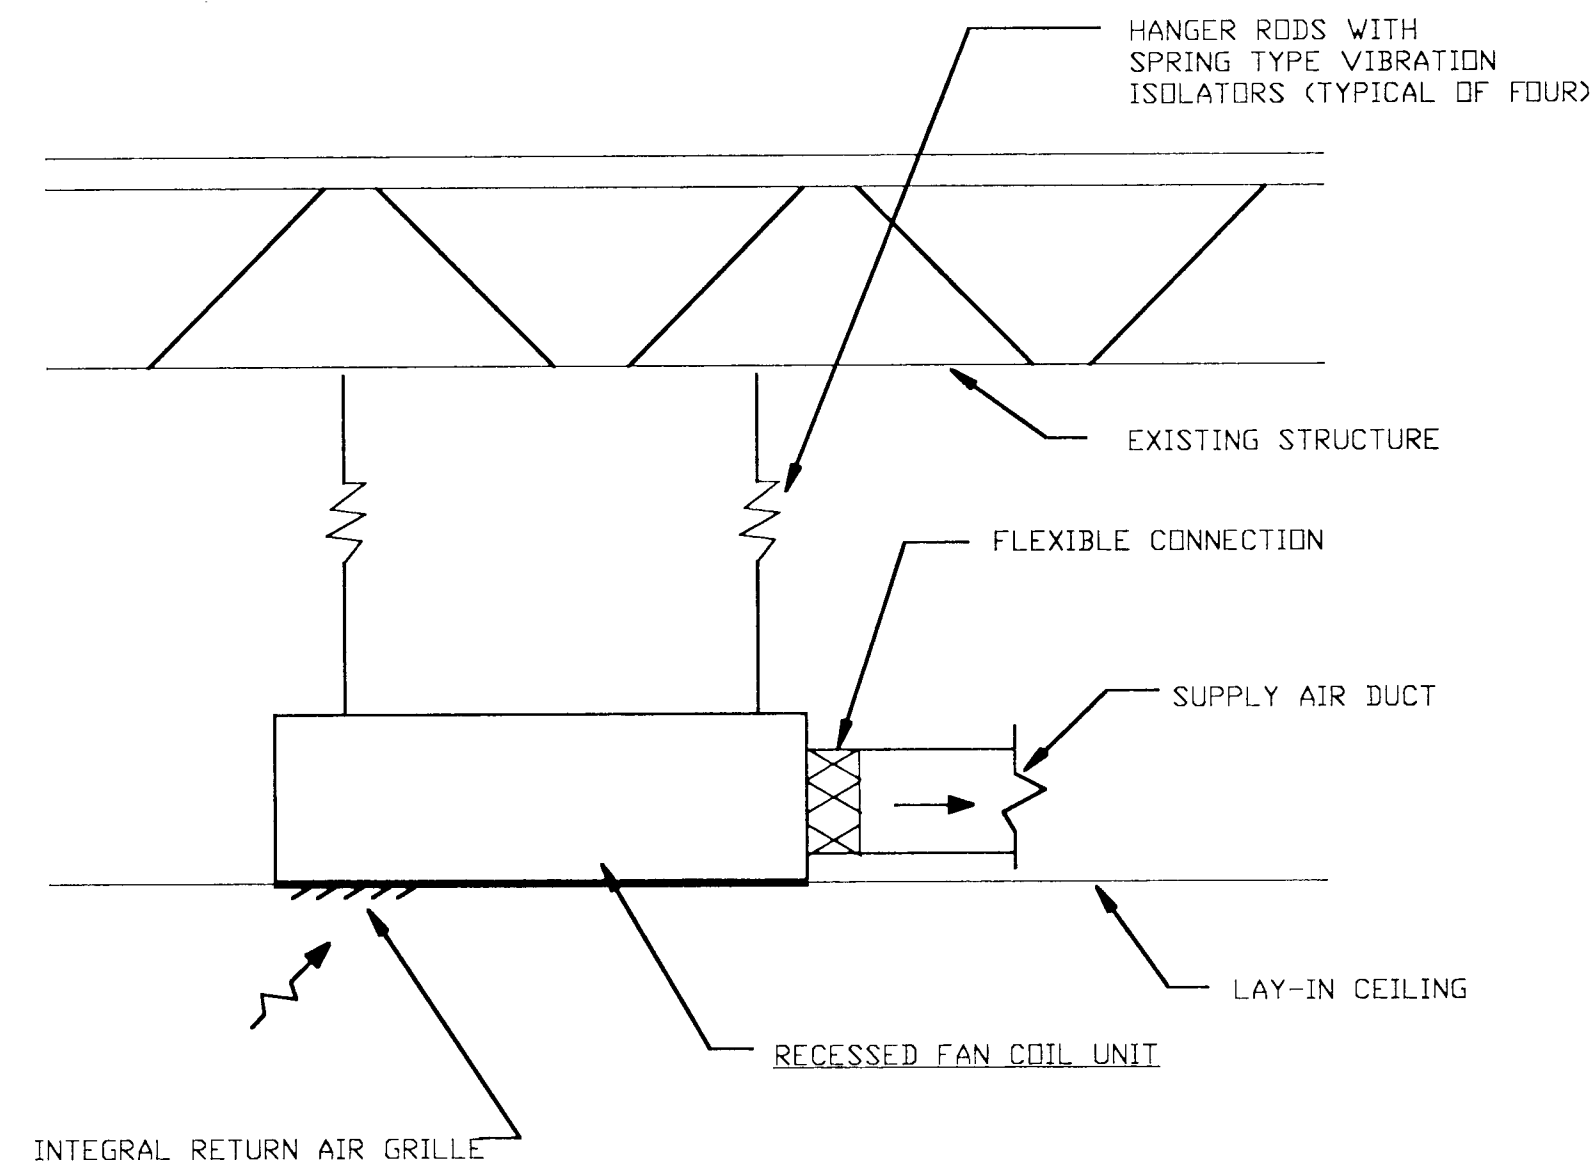


RECESSED CABINET UNIT HEATER DETAIL

NO SCALE

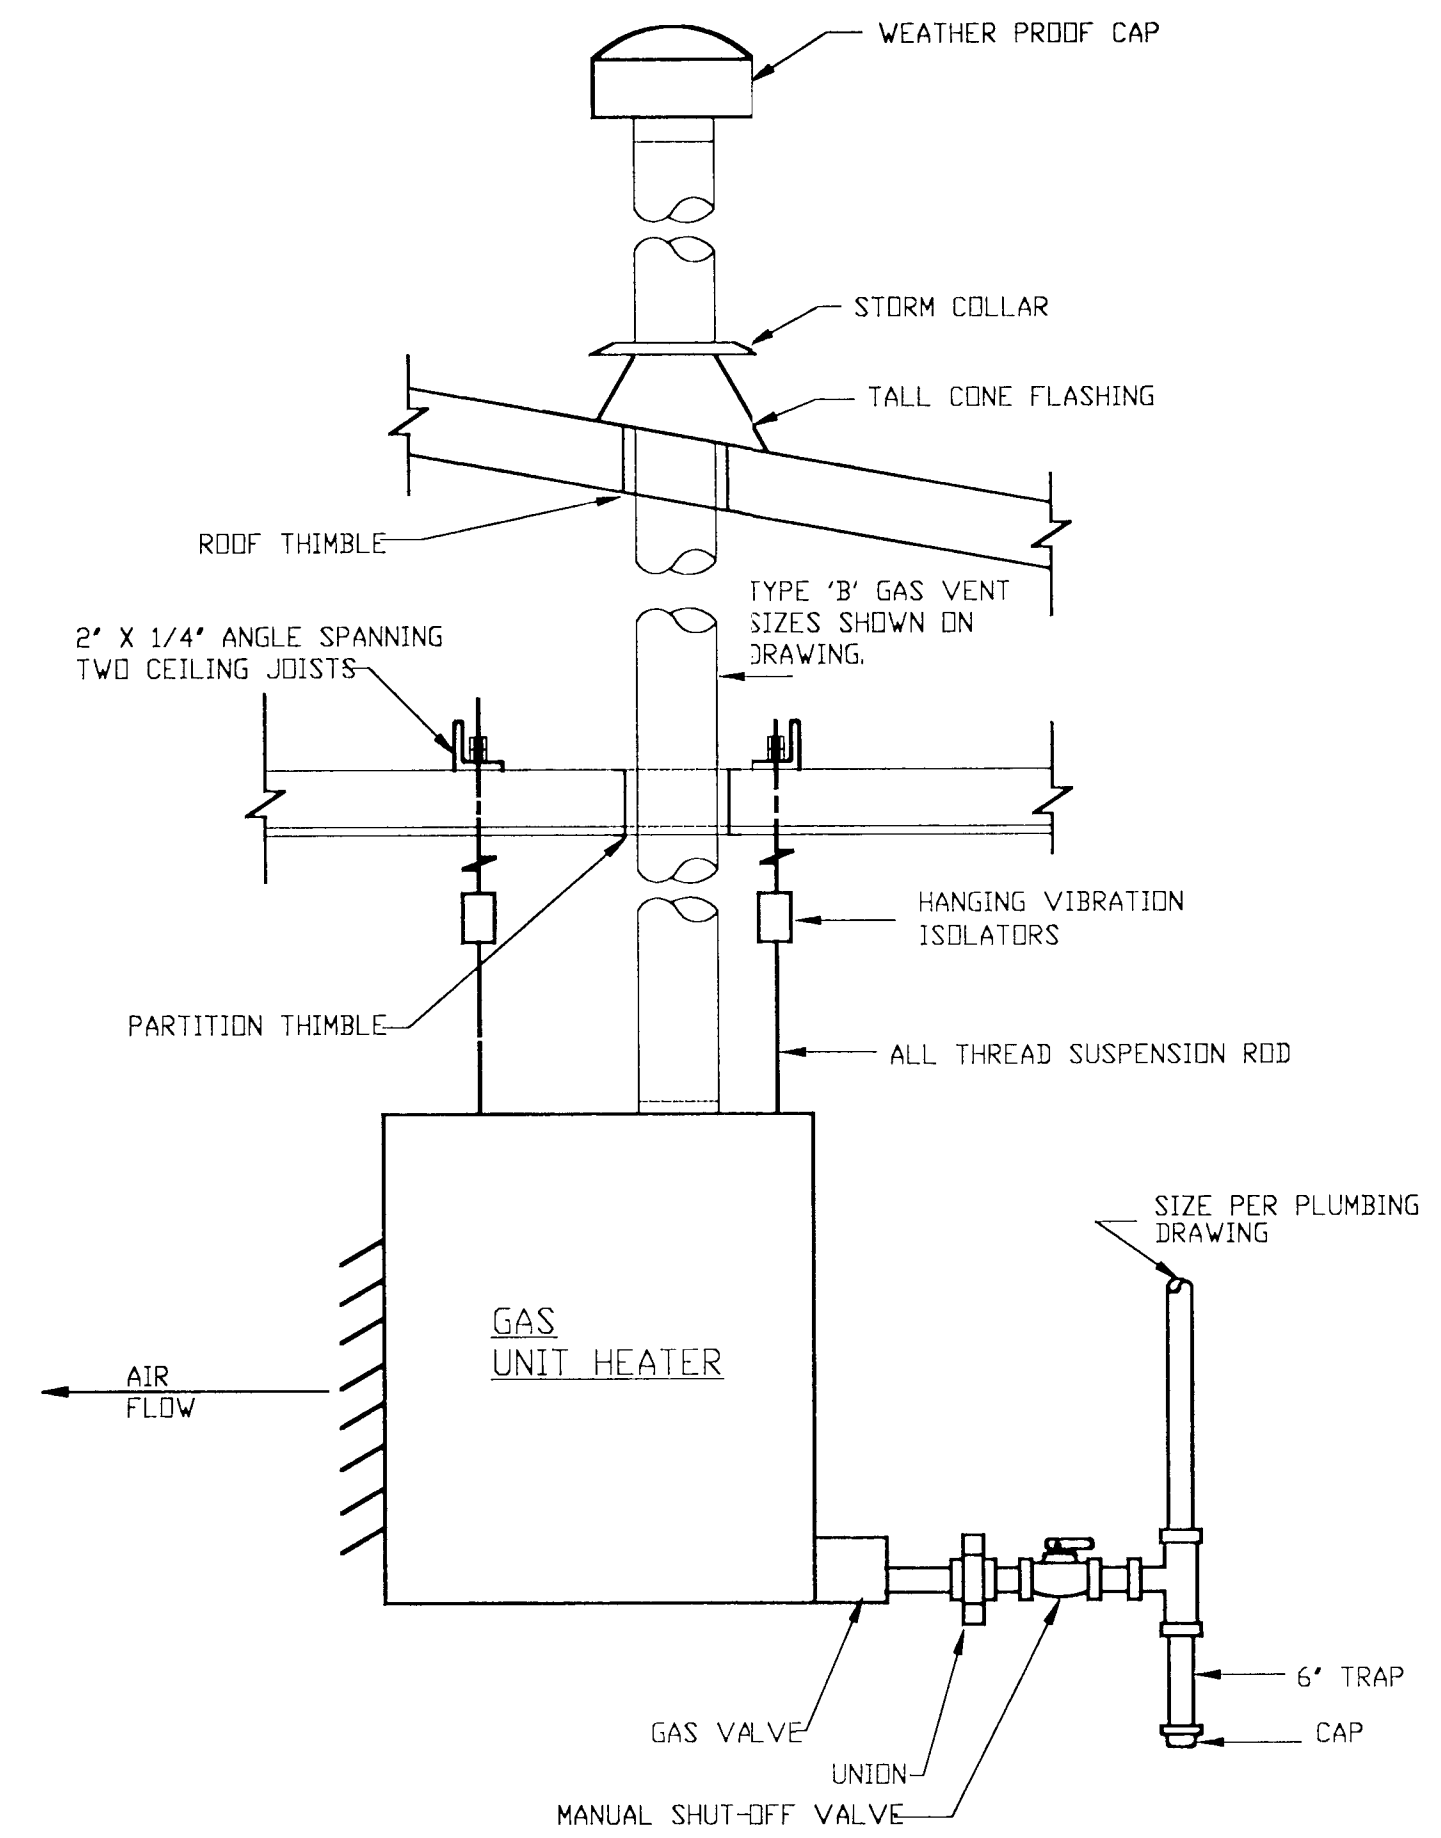

GAS UNIT HEATER DETAIL

NO SCALE

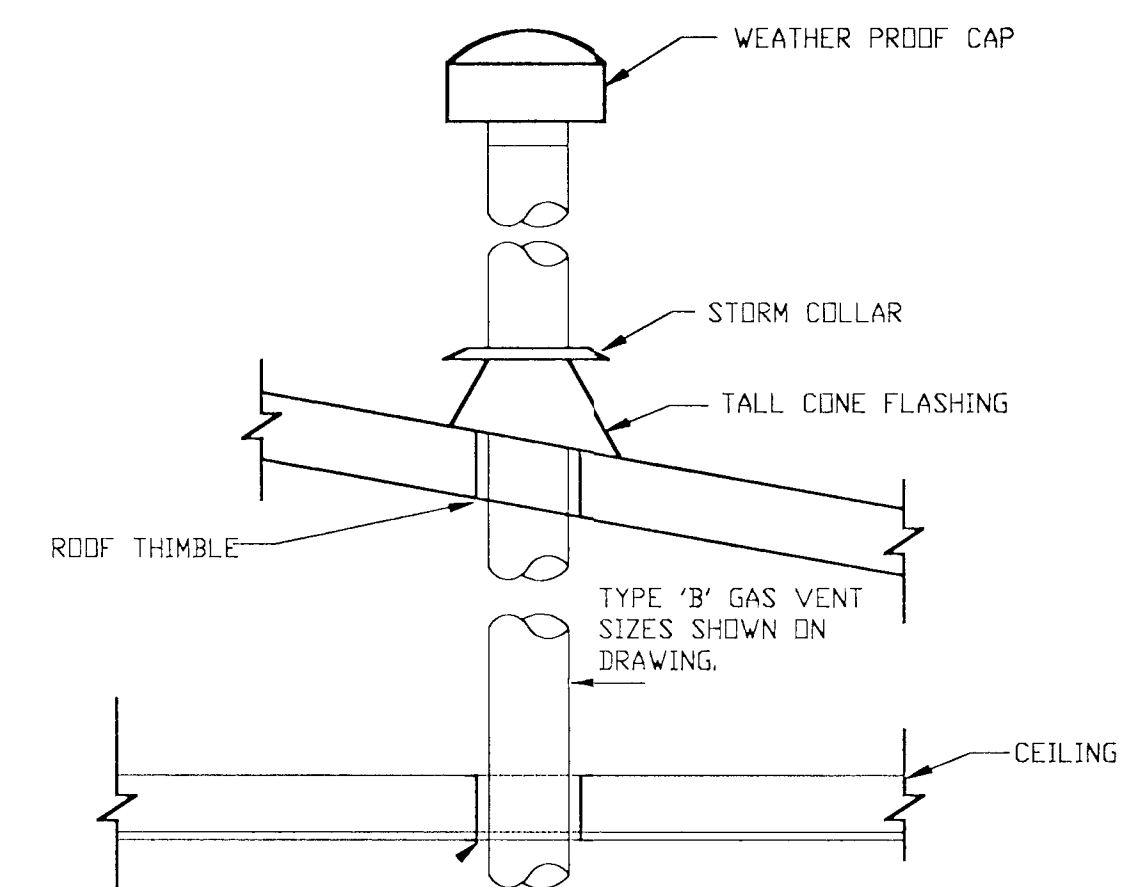

AIR HANDLING UNIT & WATER HEATER FLUE DETAIL

NO SCALE



CERTIFIED

William L. McQuire

THE ODLE MCQUIRE & SHOOK CORPORATION
ARCHITECTURE • ENGINEERING • LANDSCAPE ARCHITECTURE • INTERIOR DESIGN
8785 NORTH STATE ROAD 37, POST OFFICE BOX 2149, BLOOMINGTON, INDIANA 47402, 812/878-2020
8275 ALLISON POINTE TRAIL, POST OFFICE BOX 50428, INDIANAPOLIS, INDIANA 46250, 317/842-0000


REVISIONS

As Designed Under the Odle McQuire & Shook Corporation Seal. Copyright is hereby asserted. All rights reserved. No part of this drawing may be reproduced or transmitted in any form or by any means electronic or mechanical, including photocopying, recording, or by any information storage and retrieval system, without permission in writing from The Odle McQuire & Shook Corporation.

MICHIGAN CITY SPORTS COMPLEX
AMES FIELD
MICHIGAN CITY, INDIANA

PROJECT NO. 03062
DATE MAY 31, 1984
drawn by: KCS
checked by: WLM

M302
HVAC DETAILS

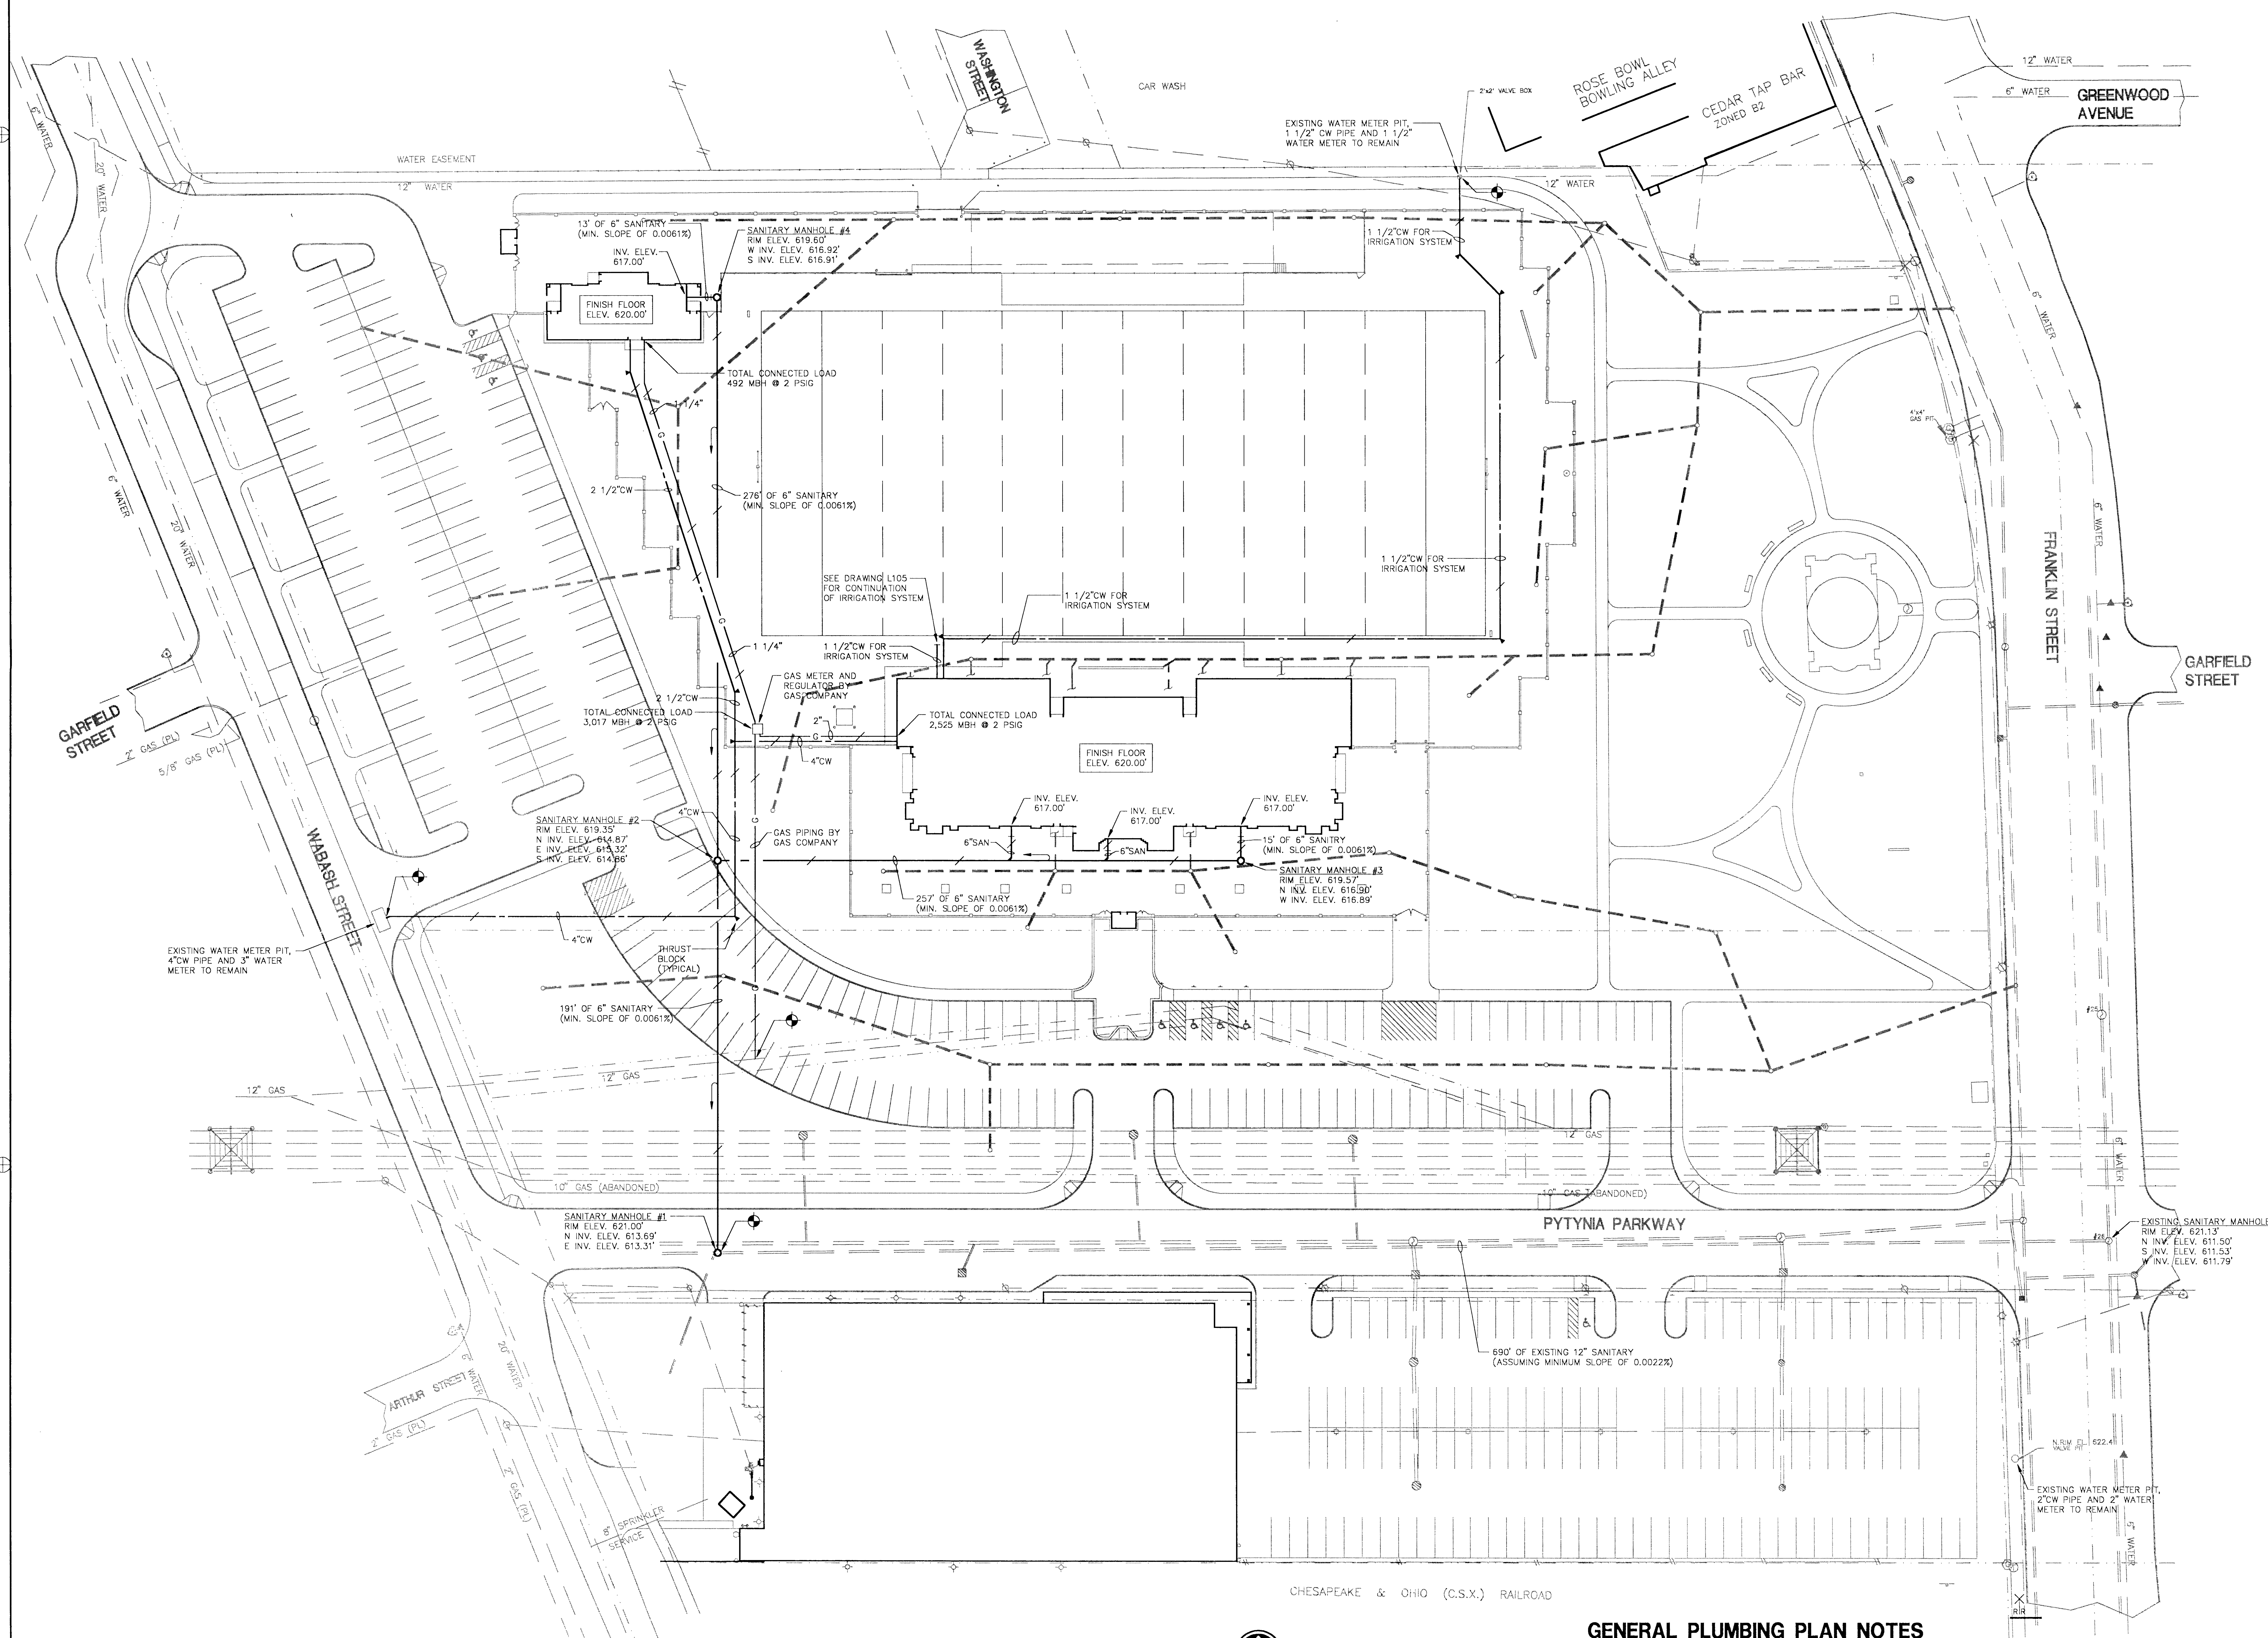


PLUMBING SITE PLAN

SCALE: 1" = 30'-0"



GENERAL PLUMBING PLAN NOTES

- 1. CONTRACTOR TO FIELD VERIFY ALL INVERT ELEVATIONS PRIOR TO INSTALLATION
- 2. CONTRACTOR TO FIELD VERIFY ALL EXISTING UTILITIES PRIOR TO ANY EXCAVATING.

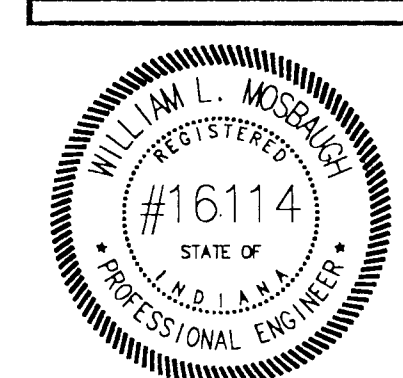

CERTIFIED

THE ODLE MCGUIRE & SHOOK CORPORATION
ARCHITECTURE • ENGINEERING • LANDSCAPE ARCHITECTURE • INTERIOR DESIGN
6765 NORTH STATE ROAD 37, POST OFFICE BOX 2149, BLOOMINGTON, INDIANA 47402, 812/976-2020
8275 ALLISON POINTE TRAIL, POST OFFICE BOX 50426, INDIANAPOLIS, INDIANA 46250, 317/842-0000


REVISIONS

© Copyright 1994 by THE ODLE MCGUIRE & SHOOK CORPORATION. Copyright includes architectural work, building design, plans or drawings, and specifications. Architectural work is the sole property of the corporation and its use without written permission is prohibited.

MICHIGAN CITY SPORTS COMPLEX
AMES FIELD
MICHIGAN CITY, INDIANA

PROJECT NO. 93052
DATE: MAY 31, 1994
drawn by: PJD
checked by: WLM

P101
PLUMBING SITE PLAN

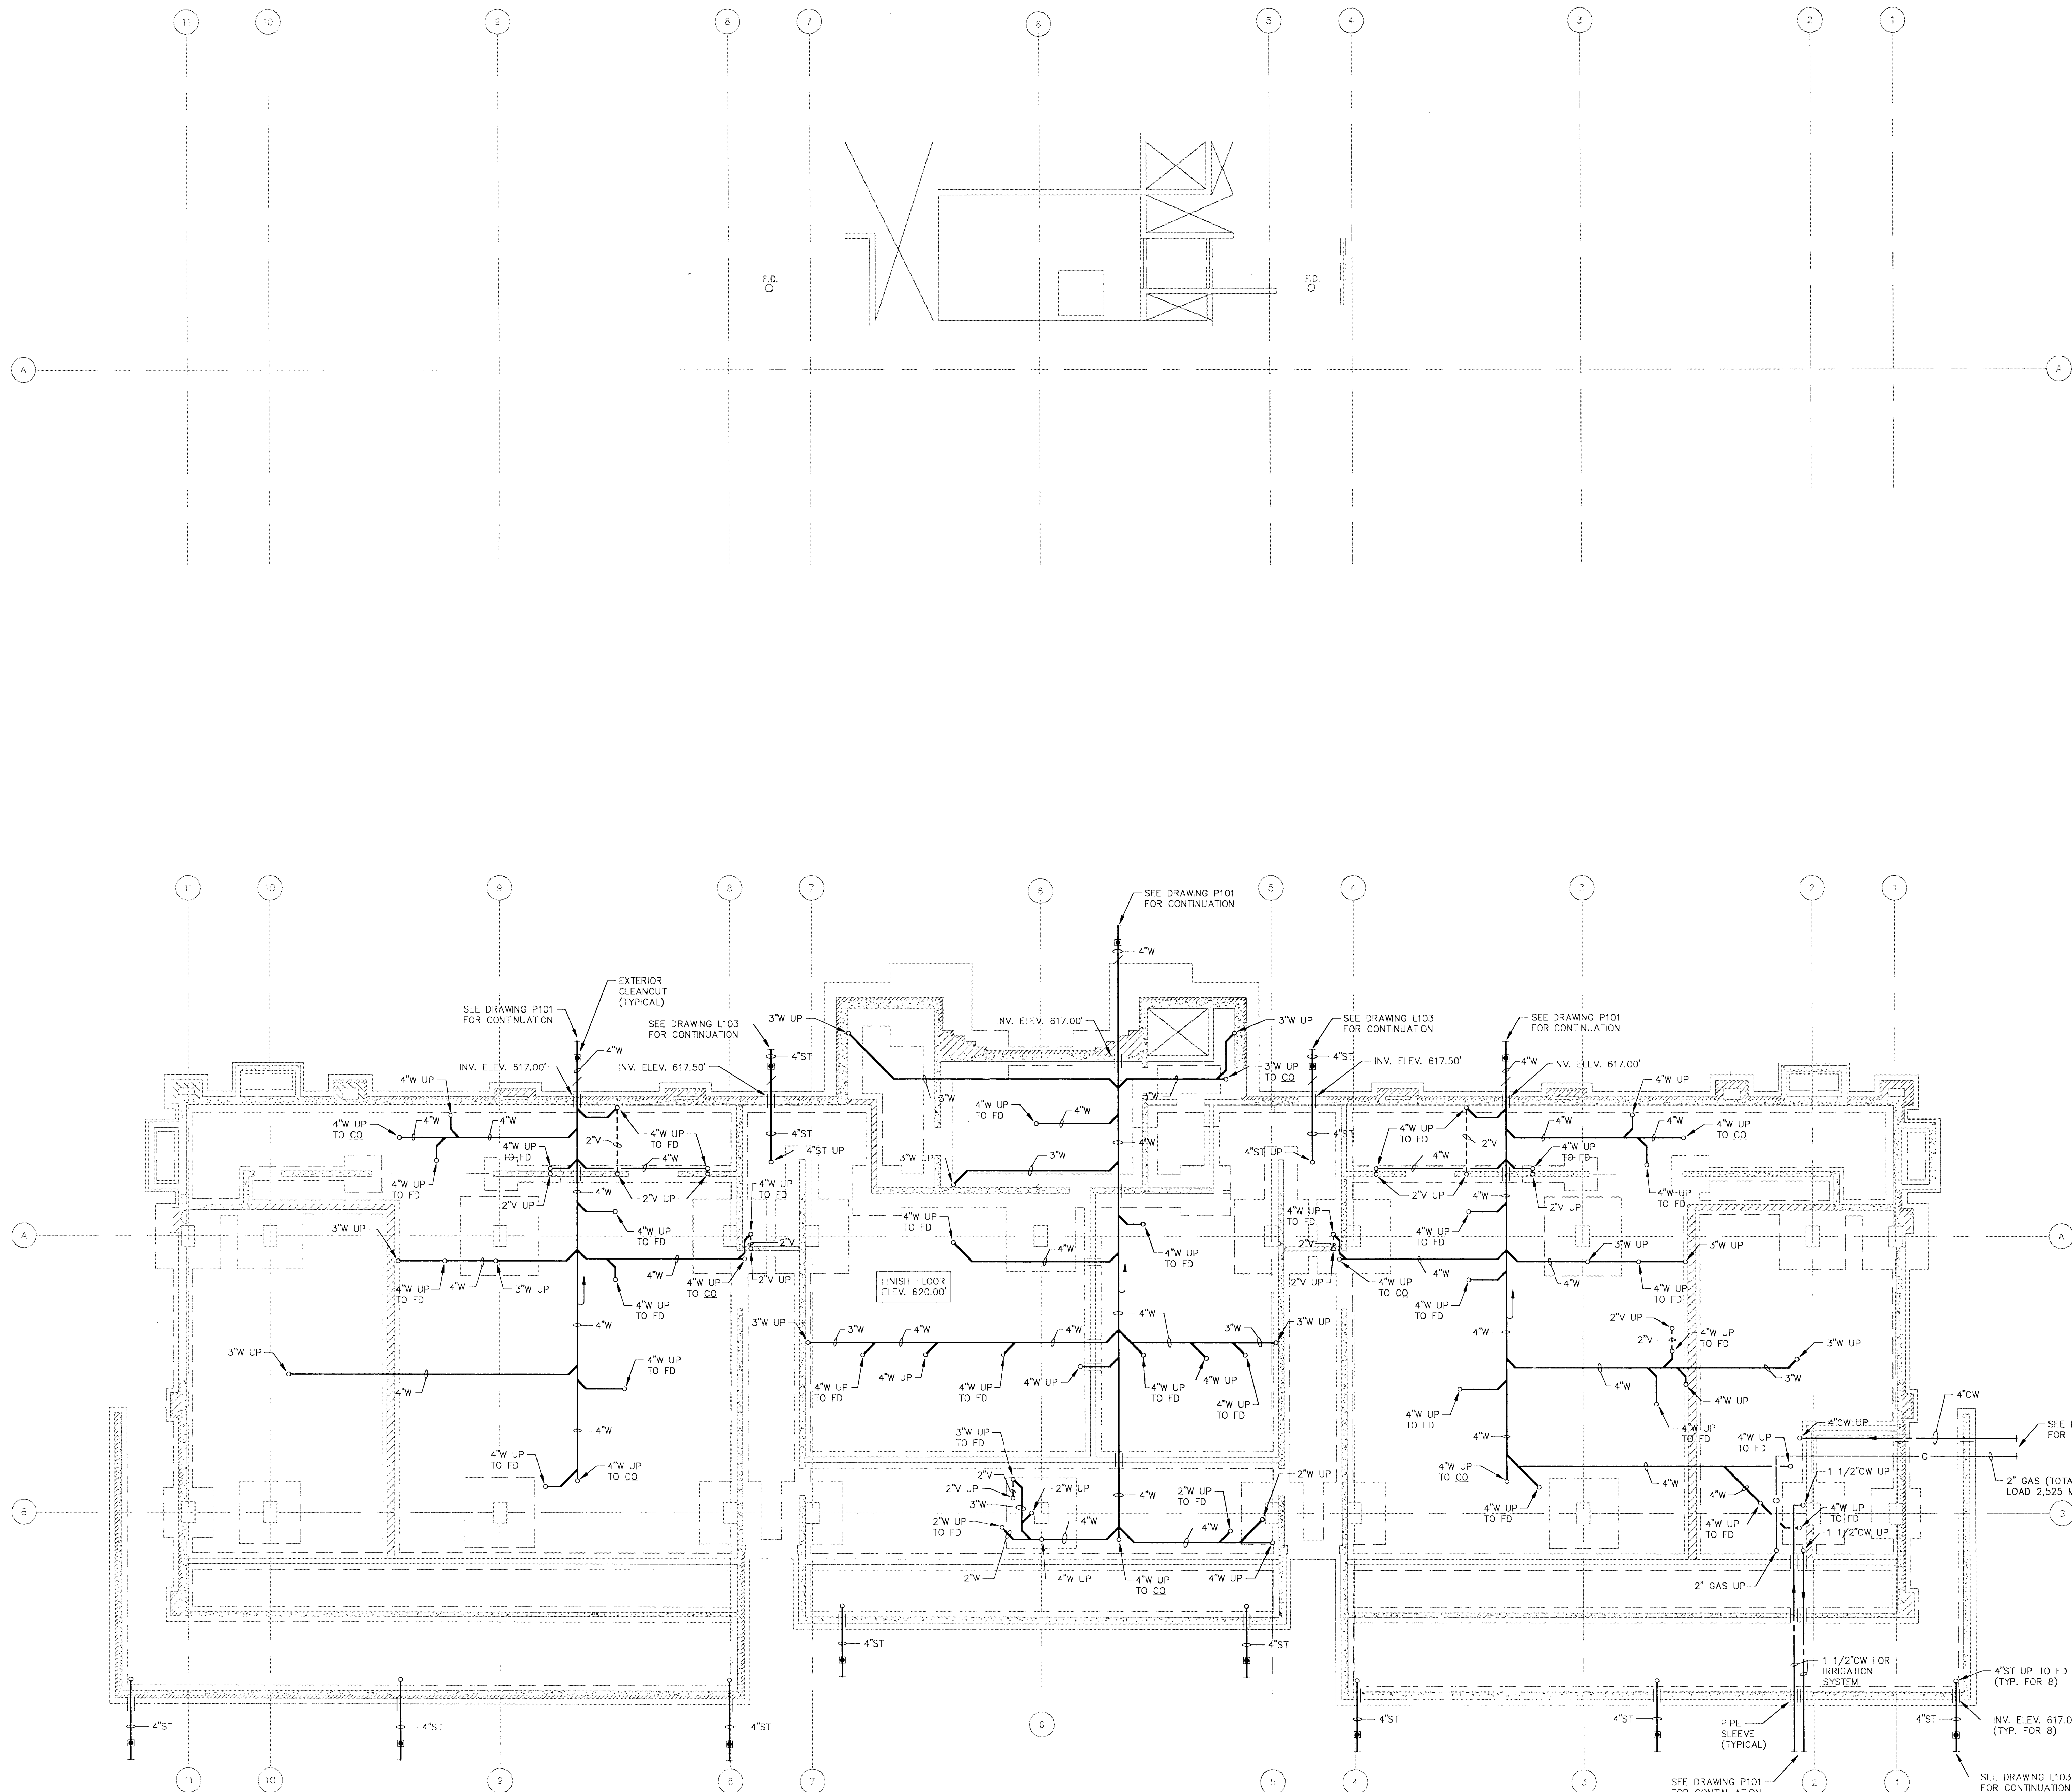

PLUMBING FOUNDATION FOOTBALL STADIUM PLAN
SCALE: 1/8" = 1'-0"



CERTIFIED

THE ODLE MCGUIRE & SHOOK CORPORATION
ARCHITECTURE • ENGINEERING • LANDSCAPE ARCHITECTURE • INTERIOR DESIGN
8786 NORTH STATE ROAD, 37, POST OFFICE BOX 7448, BLOOMINGTON, INDIANA 47402, 817/876-2020
8275 ALLISON POINTE TRAIL, POST OFFICE BOX 50428, INDIANAPOLIS, INDIANA 46250, 317/842-0000




REVISIONS

© Copyright 1994 by THE ODLE MCGUIRE & SHOOK CORPORATION. Copyright includes architectural work, building design, plans or drawings, and specifications. Architectural work is the original form as well as the arrangement and composition of space and elements in the design. Reproduction without written permission is prohibited.

MICHIGAN CITY SPORTS COMPLEX
AMES FIELD
MICHIGAN CITY, INDIANA

PROJECT NO. 93052
DATE: MAY 31, 1994
drawn by: PJD
checked by: WLM

P201
PLUMBING FOUNDATION
FOOTBALL STADIUM PLAN

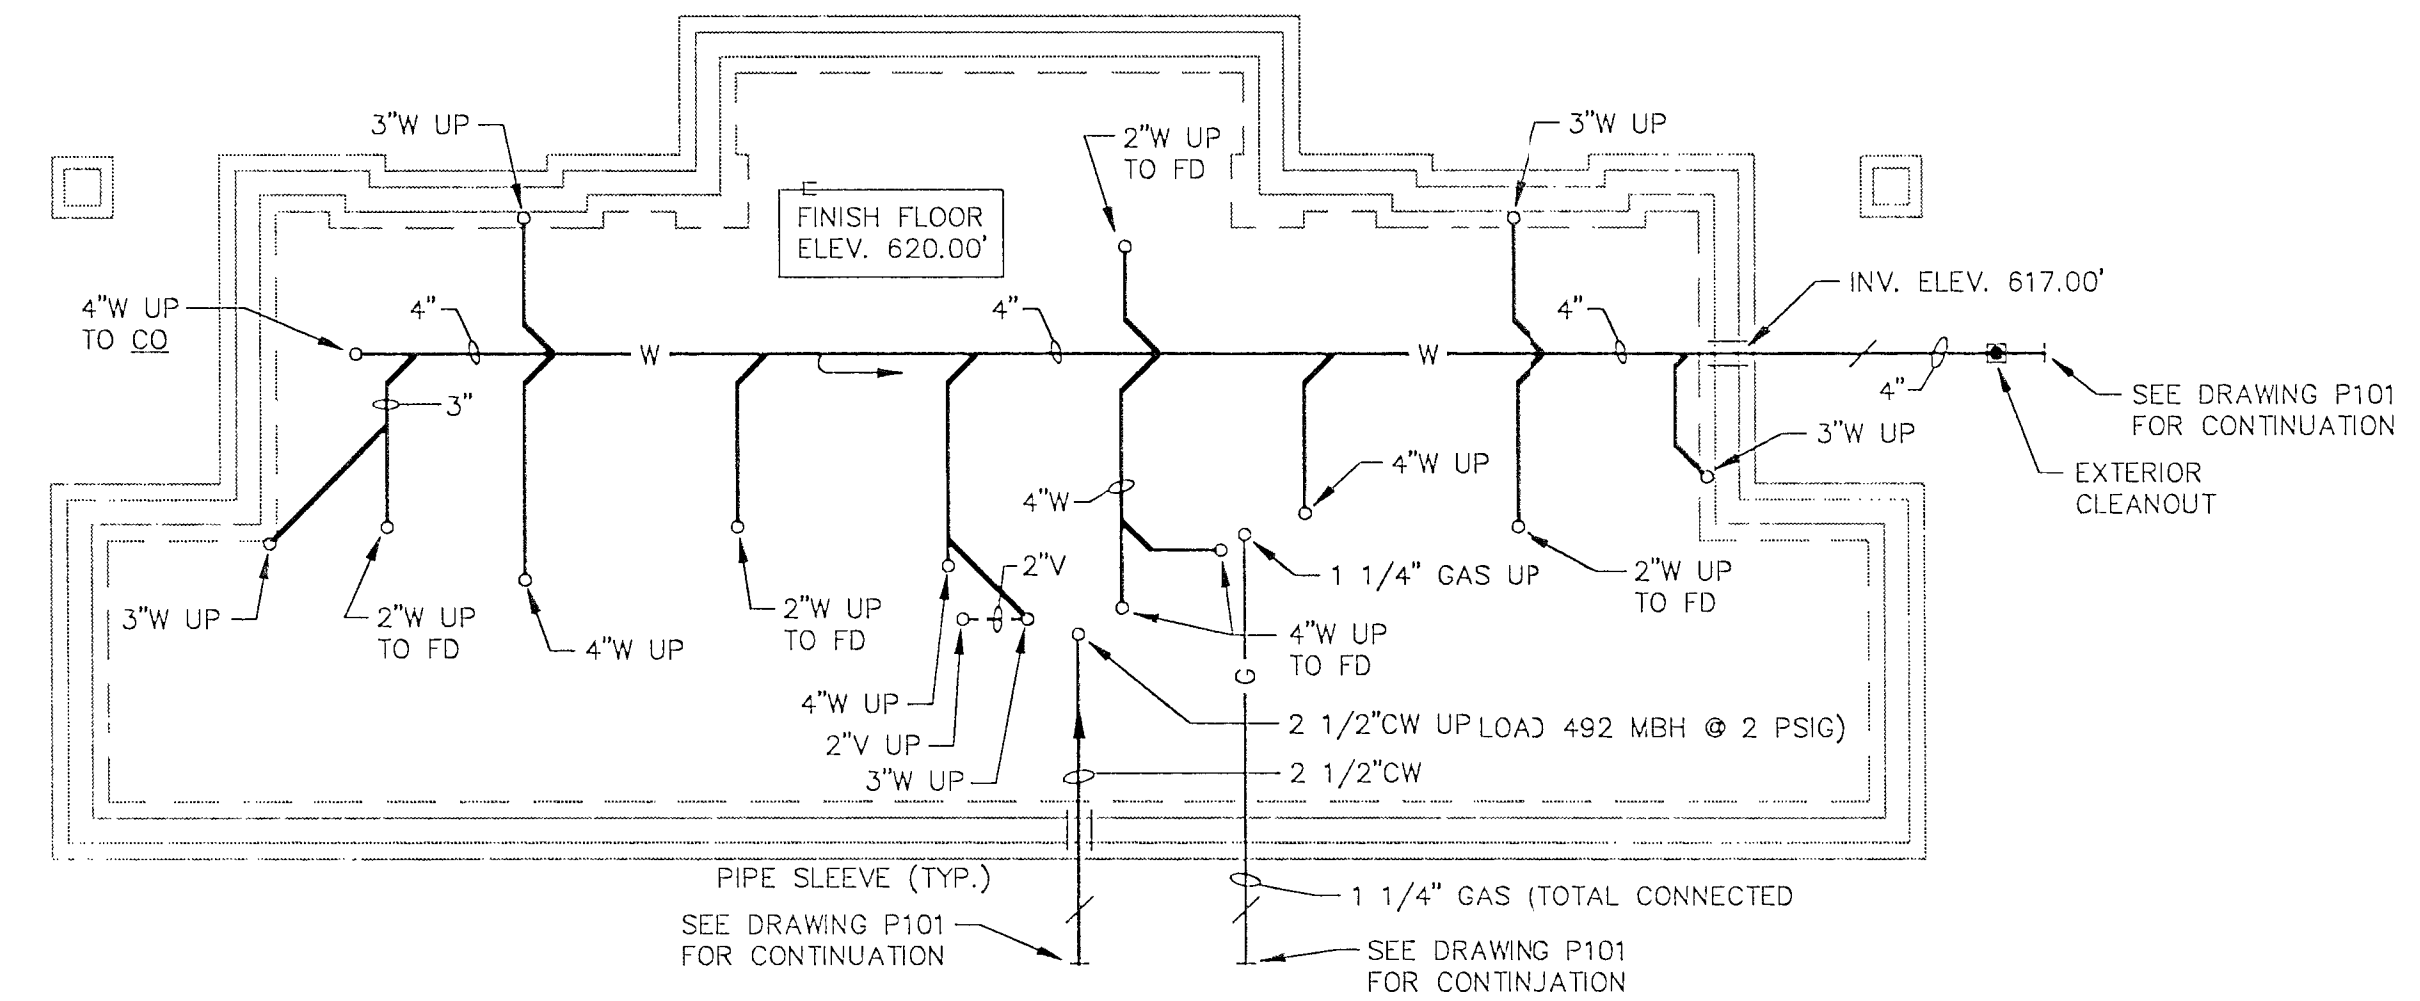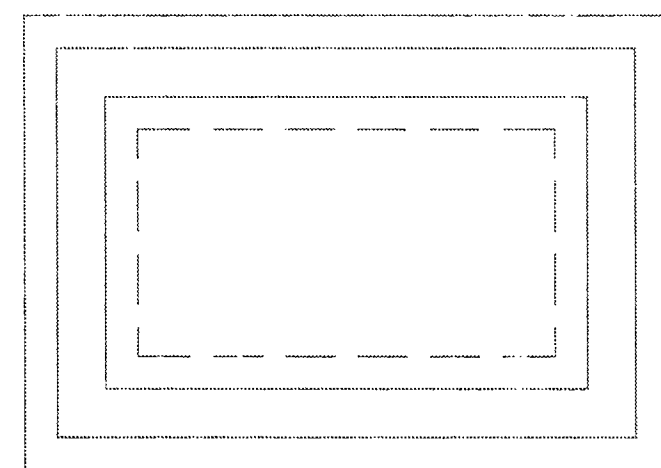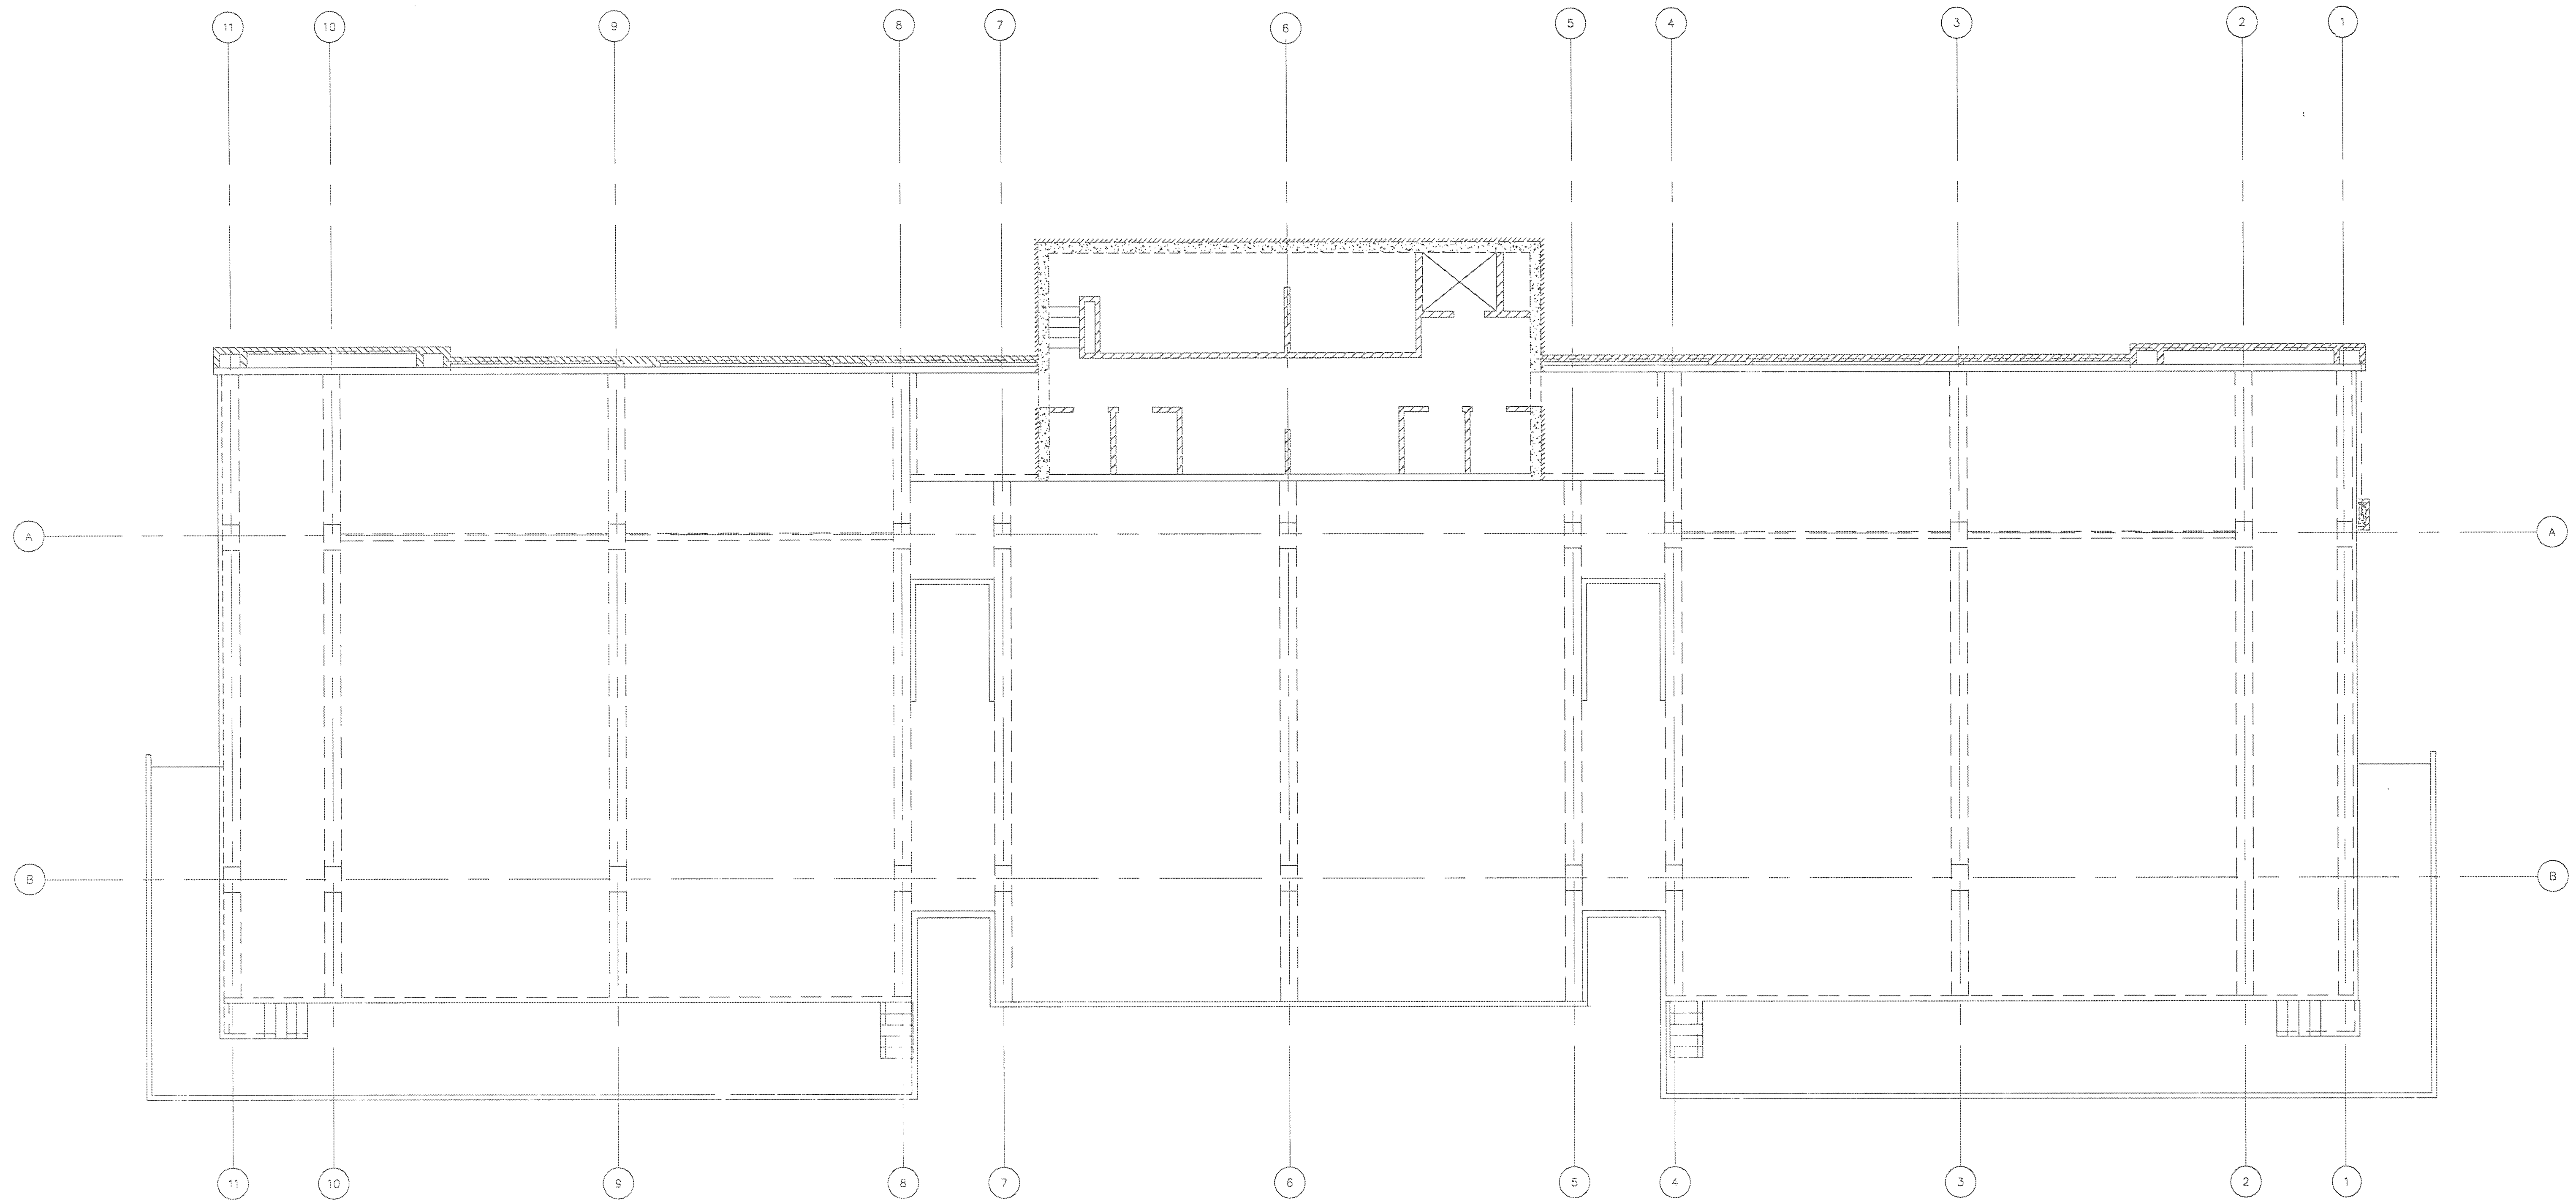

PLUMBING FOUNDATION VISITOR TOILET AND CONCESSION PLAN
SCALE: 1/8" = 1'-0"



CERTIFIED
William L. Mosley

THE ODLE MCGUIRE & SHOOK CORPORATION
ARCHITECTURE • ENGINEERING • LANDSCAPE ARCHITECTURE • INTERIOR DESIGN
6765 NORTH STATE ROAD 37, POST OFFICE BOX 2148, BLOOMINGTON, INDIANA 47402, 812/876-2020
8275 ALLISON POINTE TRAIL, POST OFFICE BOX 50428, INDIANAPOLIS, INDIANA 46250, 317/842-0000

REVISIONS

© Copyright 1994 by THE ODLE MCGUIRE & SHOOK CORPORATION. Copyright includes architectural work, building design, plans or drawings, and specifications. Architectural work is the overall form as well as the arrangement and composition of spaces and elements in the design. Reproduction without written permission is prohibited.


MICHIGAN CITY SPORTS COMPLEX
AMES FIELD
MICHIGAN CITY, INDIANA

PROJECT NO. 93052
DATE MAY 31, 1994
drawn by: PJD
checked by: WLM

P202

PLUMBING FOUNDATION
VISITOR TOILET AND
CONCESSION PLAN

F:\PLUMBING\93052\3052P202 05-31-94 10:44:22

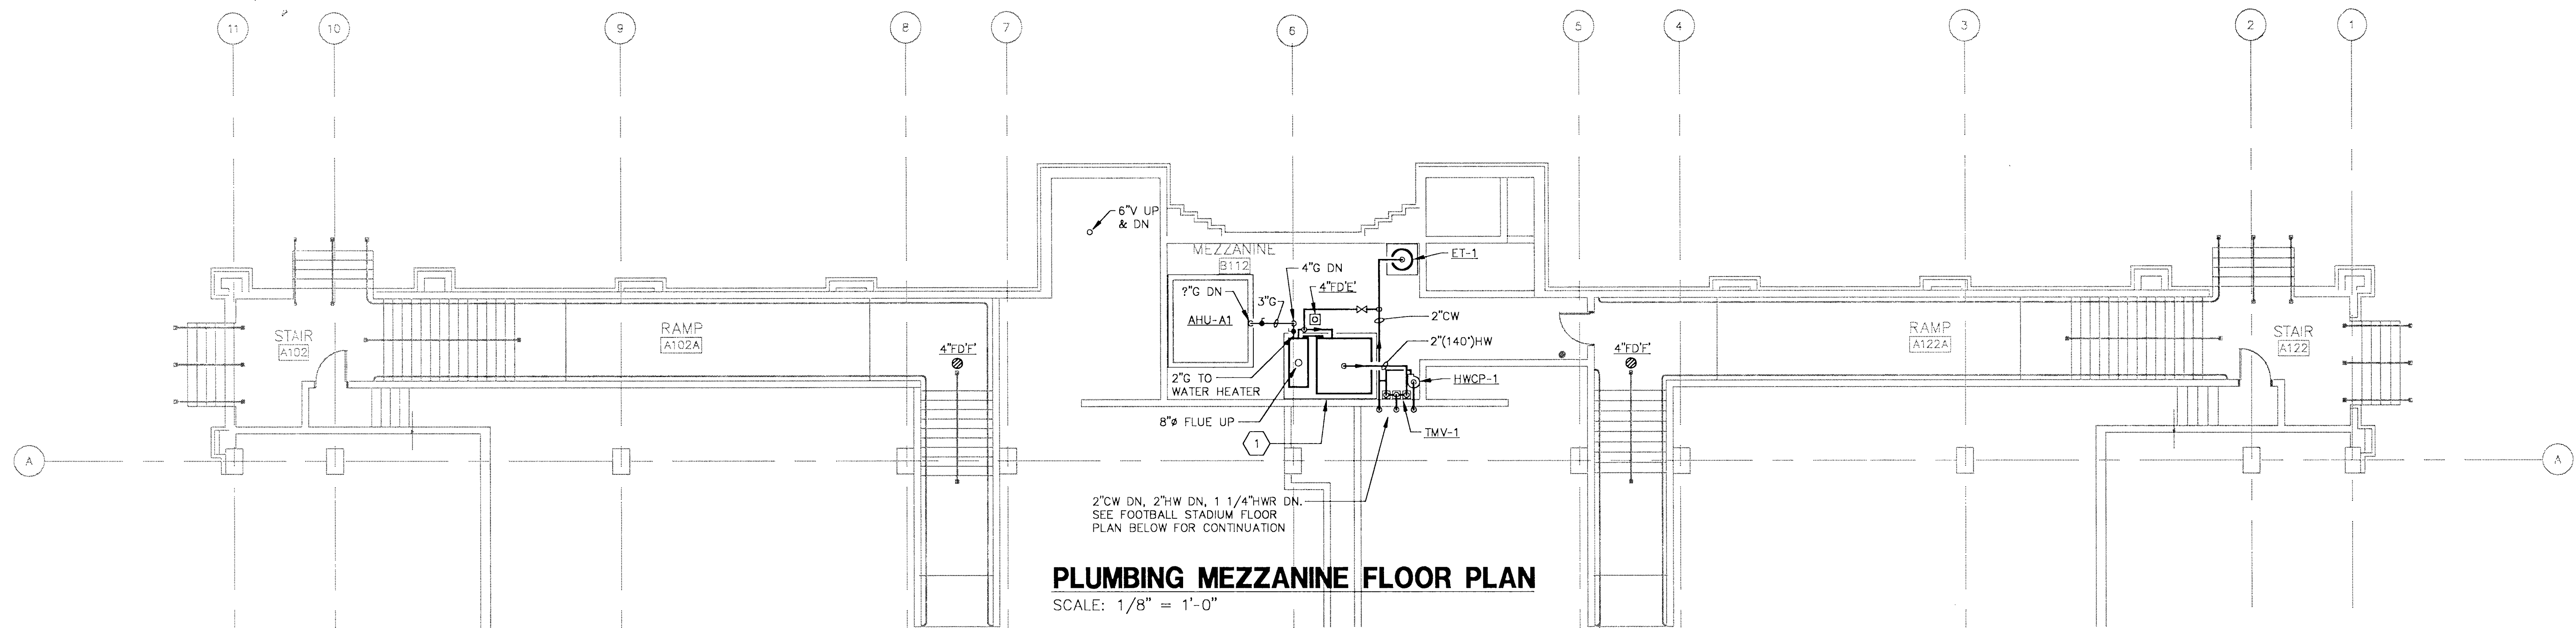

PLUMBING MEZZANINE FLOOR PLAN

SCALE: 1/8" = 1'-0"


GENERAL PLUMBING PLAN NOTES

1. SLOPE ALL DOMESTIC WATER PIPING TO ALLOW FOR OFF-SEASON DRAIN DOWN.
2. IN OFF-SEASON PERIODS WHEN THE HEATING SYSTEMS ARE TURNED OFF AND ALL DOMESTIC WATER LINES ARE DRAINED, ALL FLUSH VALVE FIXTURES SHALL BE FLUSHED AND ALL PLUMBING FIXTURE TRAPS SHALL BE FILLED WITH ANTI-FREEZE.

PLUMBING PLAN NOTES

1. WATER HEATER (WH-1). SEE DETAIL ON DRAWING P502.
2. BFP-1. SEE DETAIL ON DRAWING P502.
3. BFP-2. SEE DETAIL ON DRAWING P502.
4. 2" CW DN, 2" V RISE, 3" W DN. PROVIDE WHA 'B' ON COLD WATER BRANCH BEFORE LAST FIXTURE CONNECTION.
5. 3/4" CW & HW DROP, 2" V RISE.
6. 1 1/2" CW DROP, 3/4" HW DROP, 2" V RISE, 4" W DN.
7. 1" CW DROP, 1" HW DROP, 2" V RISE, 3" W DN, 3/4" HW DROP. CONNECT TO HOT WATER SUPPLY AFTER LAST FIXTURE CONNECTION.
8. 2" CW DROP, 2" V RISE, 4" W DN. PROVIDE WHA 'B' ON COLD WATER BRANCH BEFORE LAST FIXTURE CONNECTION.
9. 2" V RISE.
10. 3/4" CW DROP.
11. 3/4" CW & HW DROP, 1 1/2" V RISE, 2" W DN.

12. 2" V RISE, 3" W DN.
13. 3/4" HW DROP. CONNECT TO HOT WATER SUPPLY AFTER LAST FIXTURE CONNECTION.
14. 1 1/2" CW DROP, 2" V RISE, 4" W DN. PROVIDE WHA 'A' ON COLD WATER BRANCH BEFORE LAST FIXTURE CONNECTION.
15. 2" CW DROP. PROVIDE WHA 'B' ON COLD WATER BRANCH BEFORE LAST FIXTURE CONNECTION.
16. 4" V RISE, 4" W DN.
17. 2 1/2" CW DROP. PROVIDE WHA 'D' ON COLD WATER BRANCH BEFORE LAST FIXTURE CONNECTION.
18. 1" CW & HW DROP.
19. 2 1/2" CW DROP, 1" HW DROP. PROVIDE WHA 'E' ON COLD WATER BRANCH BEFORE LAST FIXTURE CONNECTION.
20. 4" INCOMING WATER SERVICE. SEE DRAWING P201 FOR CONTINUATION.
21. 1 1/2" INCOMING WATER SERVICE FOR IRRIGATION SYSTEM. SEE DRAWING P201 FOR CONTINUATION.
22. 2" INCOMING GAS SERVICE. SEE DRAWING P201 FOR CONTINUATION.
23. 2" TEMPERED WATER DROP. ROUTE PIPING IN SHOWER PANEL.
24. 2" CW UP, 2" HW UP, 1 1/4" HW UP. SEE MEZZANINE FLOOR PLAN ABOVE FOR CONTINUATION.
25. 4" W DN. CONNECT TO WASTE PIPING IN CHASE.

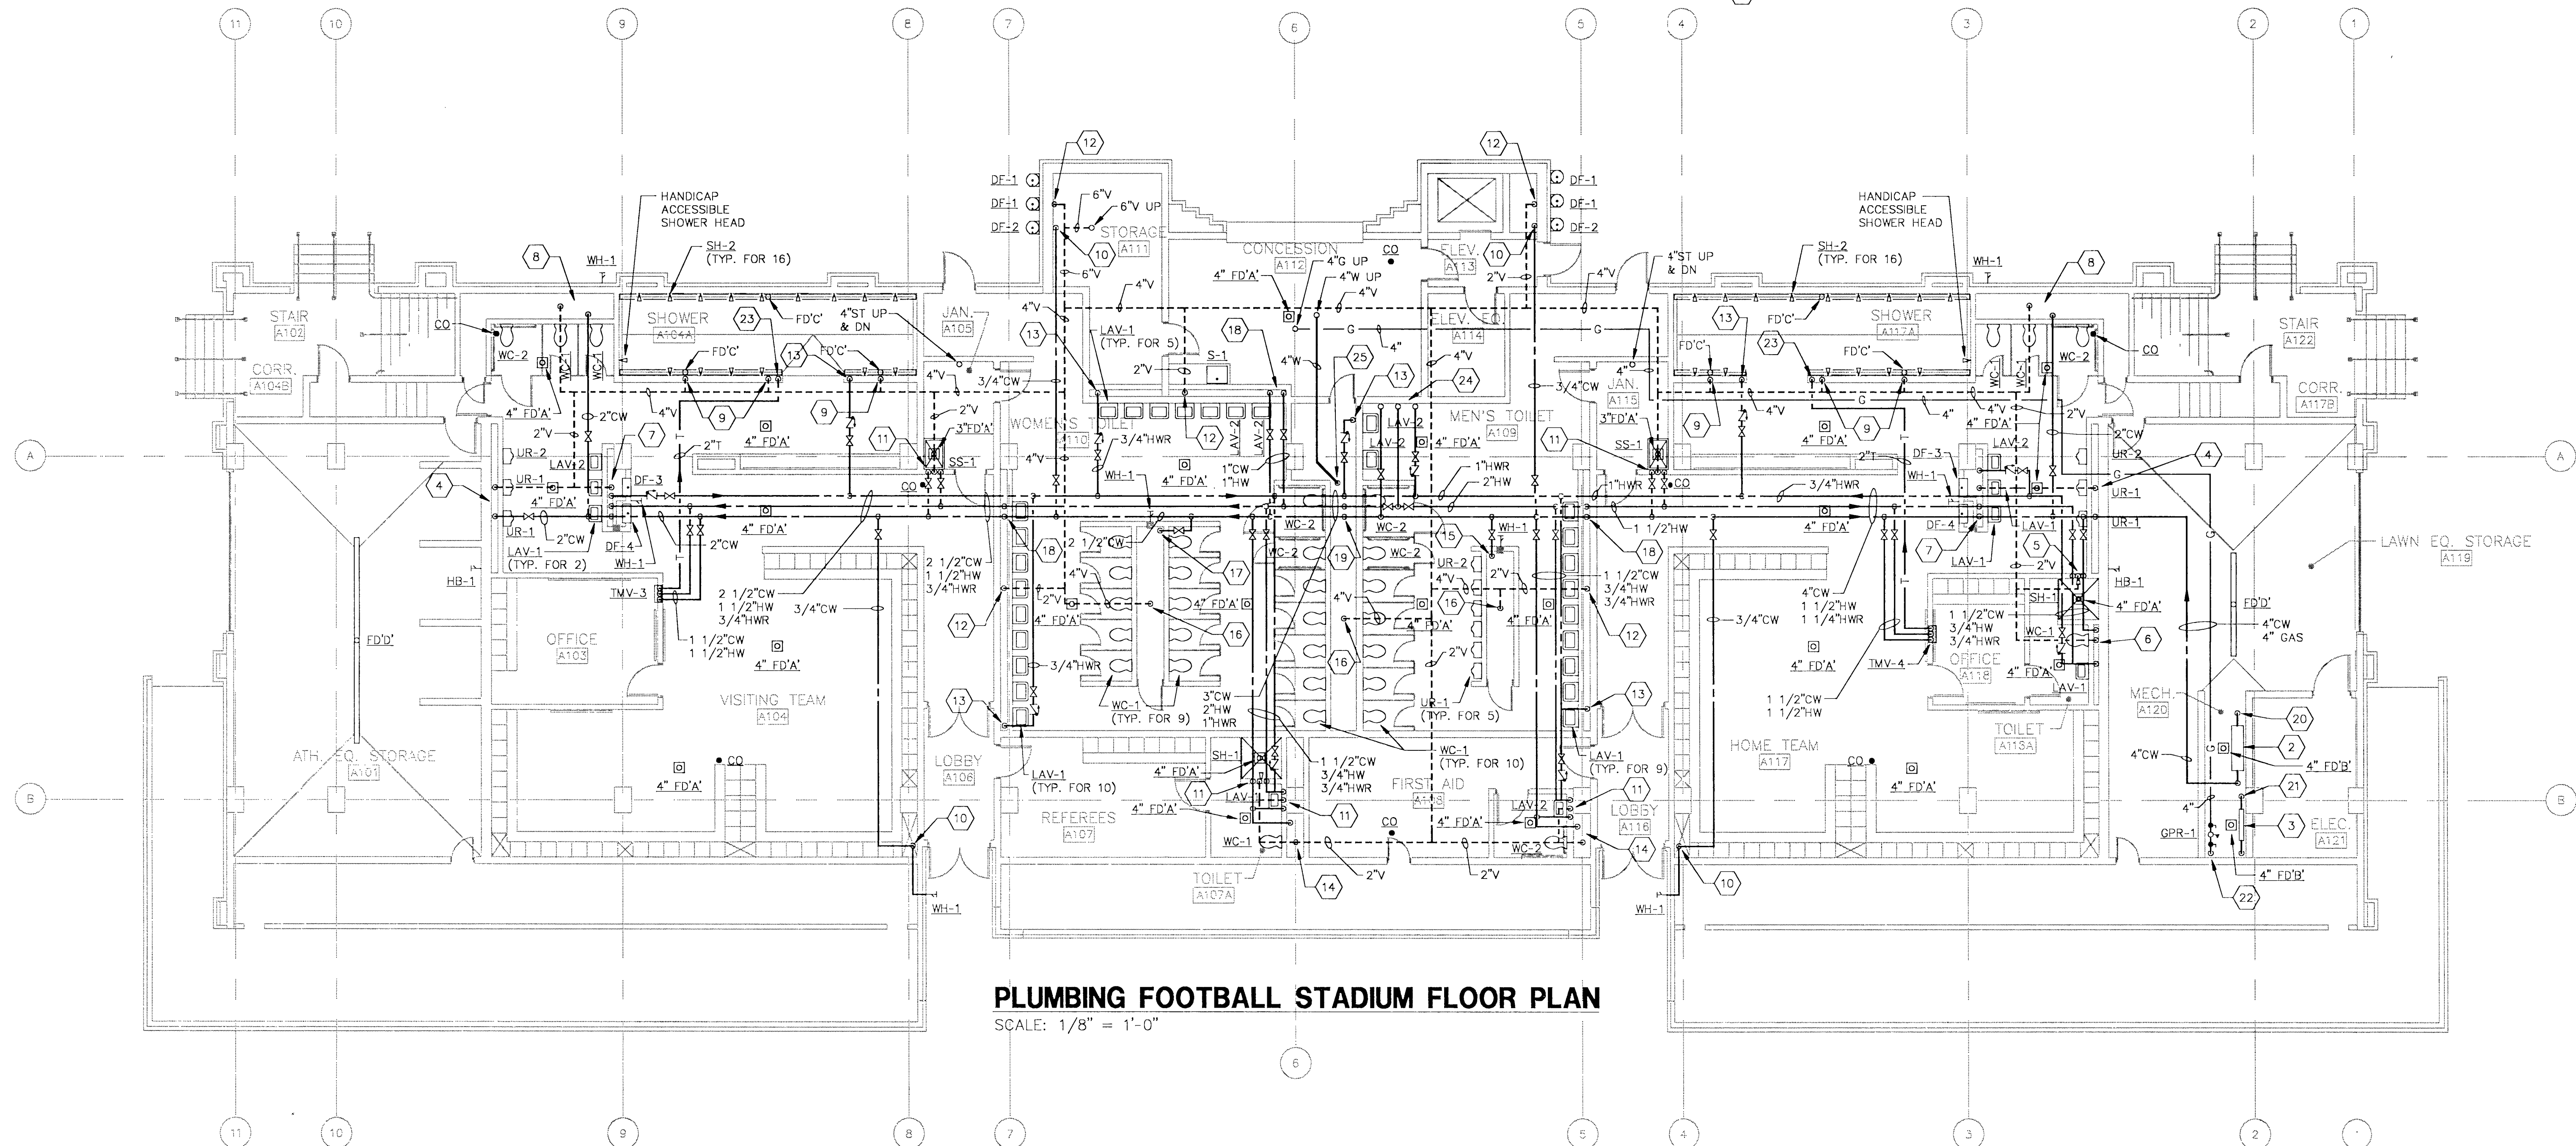

PLUMBING FOOTBALL STADIUM FLOOR PLAN

SCALE: 1/8" = 1'-0"



CERTIFIED

THE ODLE MCCUIRE & SHOOK CORPORATION
ARCHITECTURE • ENGINEERING • LANDSCAPE ARCHITECTURE • INTERIOR DESIGN
6765 NORTH STATE ROAD 37, POST OFFICE BOX 2149, BLOOMINGTON, INDIANA 47402, 812/876-2020
8275 ALISON POINTE TRAIL, POST OFFICE BOX 50428, INDIANAPOLIS, INDIANA 46250

REVISIONS

© Copyright 1994 by THE ODLE MCCUIRE & SHOOK CORPORATION. Copyright includes architectural work, building design, plans or drawings, and specifications. Architectural work in the serial form as well as the arrangement and composition of space and elements in the design. Reproduction without written permission is prohibited.

MICHIGAN CITY SPORTS COMPLEX
AMES FIELD
MICHIGAN CITY, INDIANA

PROJECT NO. 93052
DATE MAY 31, 1994
drawn by: PJD
checked by: WLM

P203

PLUMBING FOOTBALL STADIUM AND MEZZANINE FLOOR PLANS


VAVLE IDENTIFICATION CHART FOR		PLUMBING	SYSTEM
Job Name:		Installed by:	
AMES FIELD - STADIUM		Industrial Maintenance & Mechanical Contractors, Inc.	
Date:			
Valve No.	Location	Purpose	
1	Mechanical Room A120	Main Shut-off (Stadium, Visitor Toilet & Conc. & Sprinkler System)	
2	Mechanical Room A120	Sprinkler System (Meter Inlet)	
3	Mechanical Room A120	Sprinkler System (Meter Outlet)	
4	Mechanical Room A120	By-Pass Shut-Off	
5	Mechanical Room A120	Sprinkler System (BFP Inlet)	
6	Mechanical Room A120	Sprinkler System (BFP Outlet)	
7	Mechanical Room A120	Main Shut-off (Meter Inlet)	
8	Mechanical Room A120	Main Shut-Off (Meter Outlet)	
9	Mechanical Room A120	Main Shut-off (BFP Inlet)	
10	Mechanical Room A120	Main Shut-Off (BFP Outlet)	
11	Mechanical Room A120	Main Shut-Off (Stadium)	
12	Mechanical Room A 120	Main Shut-Off (Visitor Toilet & Con	
13	Locker Rm A117 (Above Ceiling No. End of Urinal)	Urinals Cold Supply Mens Rm.A117	
14	Room A 118 (Above Shw)	Hot Supply Shw & Lav Rm A118	
15	Room A 118 (Above Shw)	Cold Supply Shw Lav & WC Room A118	
16	Room A 118 (Above Shw)	HWR Bal Valve Room A 118	
17	Room A 118 (Above Shw)	HWR Drain	
18	Room A 118 (Behind Access Panel West Wall)	Cold Water Drain RM A118	
19	Room A 118 (Behind Access Panel West Wall)	Hot Water Drain RM A118	
20	Room A 118 (Behind Access Panel West Wall)	HWR Drain RM A118	
21	Locker RM A117 (Above DrkPtn)	Cold Water Supply for Lavs & Drk.Ptns. RM A117	
22	Locker RMA117 (Above Off. RM A118 South Wall)	Cold Water Supply WCs & Outside Hose Bibb Room A 117	

VAVLE IDENTIFICATION CHART FOR <u>PLUMBING</u>			SYSTEM
Job Name: AMES FIELD - STADIUM		Installed by: Industrial Maintenance & Mechanical Contractors, Inc.	
Date:			
<u>Valve No.</u>	<u>Location</u>	<u>Purpose</u>	
23	Locker Room A117 (Above Drk. Ftn)	Hot Water Supply Lavs Room A117	
24	Locker Room A117 (Above Drk Ftn)	HWR Bal Valve Room A117 for Shower Mixing	
25	Locker Room A117 (Above Office Room A118 East Wall)	Cold Water Supply Valve Room A 117A	
26	Locker Room A117 Above Office Room A118 East Wall)	Hot Water Supply Valve Room A 117A	
27	Locker Room A117 (Behind Access Panel Under Drinking Fountain)	Hot Water Drain for Lavs Room A117	
28	Locker Room A117 (Above Shower Entrance)	HWR Bal Valve Room A117A	
29	Locker Room A117 (Above Shower Entrance)	HWR Drain Room A 117A	
30	Locker Room A117 (Overhead Between Light & Duct/Southeast Corner)	Cold Water Supply to Hose Bibb Outside Lobby A 116	
31	Lobby A116 (Above Doorway)	Hot Water Supply to Mop Sink Room A115	
32	Lobby A116 (Above Doorway)	Cold Water Supply to Mop Sink Room A115	
33	Mens Room A109 (West Wall Above Lavs)	Hot Water Supply to Lavs Room A109	
34	Mens Room A109 (West Wall Above Lavs)	Cold Water Supply to Lavs Room A109	
35	Mens Room A109 (West Wall Above Lavs)	Cold Water Supply to Stadium Outside Drk Ftns West Side	
36	Mens Room A109 (West Wall Above Lavs)	Hot Water Supply to Lav Room A108	
37	Mens Room A109 (West Wall Above Lavs)	Cold Water Supply to Lav Room A108	
38	Mens Room A109 (West Wall Above Lavs)	HWR Bal Valve Room A109	
39	Mens Room A109 (Behind Access Panel on West Wall)	Hot Water Drain Lavs Room A109	
40	Mens Room A109 (Behind Access Panel on West Wall)	Hot Water Drain Lavs Room A109	
41	First Aid Room A108 (Above Door)	HWR Drain Room A108	
42	First Aid Room A108 (Above Door)	HWR Bal Valve Room A108	
43	First Aid Room A108 (Behind Access Panel)	Cold Water Drain Room A108	
44	First Aid Room A108 (Behind Access Panel)	Hot Water Drain Room A108	

VAVLE IDENTIFICATION CHART FOR PLUMBING			SYSTEM
Job Name: AMES FIELD - STADIUM		Installed by: Industrial Maintenance & Mechanical Contractors, Inc.	
Date:			
<u>Valve No.</u>	<u>Location</u>	<u>Size</u>	<u>Purpose</u>
45	Mens Room A109 (Above Urinals)		Cold Water Supply to Urinals Room A109
46	Mens Room A109 (Above Wtr Cl.)		Hot Water Main Supply Stadium West End
47	Mens Room A109 (Above Wtr Cl.)		Hot Water Main Supply Stadium East End
48	Mens Room A109 (Above Wtr Cl.)		HWR Bal Valve Stadium West End
49	Mens Room A109 (Above Wtr Cl.)		HWR Bal Valve Stadium East End
50	Overhead in Chase Between Mens Room A109 & Womens Room A110		Cold Water Supply for Room A109 Lavs & WC's East Wall Room A110 WCs West Wall
51	Overhead in Chase Between Mens Room A109 & Womens Room A110		Hot Supply to HC Lavs Room A109
52	In Chase Between Mens Room A 109 & Womens Room A110		HWR Shut Off HC Lavs Room A109
53	In Chase Between Mens Room A 109 & Womens Room A110		HWR Bal Valve for HC Lavs Room A109
54	In Chase Between Mens Room A109 & Womens Room A110		HWR Drain Valve HC Lavs Room A109
55	In Chase Between Mens Room A109 & Womens Room A110		Hot Water Drain HC Lavs Room A109
56	In Chase Between Mens Room A109 & Womens Room A110		Cold Water Drain HC Lavs & WC Room A109 & WCs West Wall Room A110
57	In Chase Between Mens Room A109 & Womens Room A110		Cold Water Drains Lavs South Wall Room A110
58	In Chase Between Mens Room A 109 & Womens Room A110		Hot Water Drains Lavs South Wall Room A110
59	Storage Room A111		Cold Water Drain Stadium Outside Drk. Ftns (West Side)
60	In Chase Side of Elevator		Cold Water Drain Stadium Outside Drk Fountains (East Side)
61	Womens Room A110 (Above WCs On West Wall)		Cold Supply Lavs South Wall Room A107
62	Womens Room A110 (Above WCs West Wall)		Hot Supply Lavs South Wall Room A107
63	Womens Room A110 (Above Ceiling Between Banks of WCs)		Hot Supply to Room A107
64	Womens Room A110 (Above Ceiling Between Banks of WCs)		Cold Supply to Room A107

VAVLE IDENTIFICATION CHART FOR PLUMBING				SYST
Job Name: AMES FIELD - STADIUM		Installed by: Industrial Maintenance & Mechanical Contractors, Inc.		
Date:				
Valve No.	Location	Size	Purpose	
65	Womens Room A110 (Above Island Chase)		Cold Supply to Island WCs Room A110	
66	Womens Room A110 (Above Island Chase)		Cold Supply Stadium Outside Drk Fountains (East Side)	
67	Womens Room A110 (Above Lavs on South Wall)		HWR Bal Valve Lavs South Wall Room A110	
68	Womens Room A110 (Above Lavs on East Wall)		HWR Bal Valve Lavs East Wall Room A110	
69	Womens Room A110 (Above Lavs East Wall)		Cold Supply Lavs East Wall Room A110	
70	Womens Room A110 (Above Lavs East Wall)		Hot Supply Lavs East Wall Room A110	
71	Womens Room A110 (Behind Access Panel East Wall)		Cold Drain Supply Lavs East Wall Room A110	
72	Womens Room A110 (Behind Access Panel East Wall)		Hot Drain Supply Lavs East Wall Room A110	
73	Lobby A106 (Above Large Doorway)		Hot Supply Mop Sink Room A105	
74	Lobby A106 (Above Large Doorway)		Cold Supply Mop Sink Room A105	
75	Referees Room A107A (Above Shower)		HWR Drain Room A107A	
76	Referees Room A107A (Above Lav)		HWR Bal Valve Room A107A	
77	Referees Room A107A (Above Ceiling Over Access Panel)		HWR Drain Room A107A	
78	Referees Room A107 (Behind Access Panel)		Hot Drain Room A107A	
79	Referees Room A107 (Behind Access Panel)		Cold Drain Room A107A	
80	Referees Room A107 (Behind Access Panel)		HWR Drain Room A107A	
81	Locker Room A104 (Overhead South/West Corner)		Cold Supply Hose Bibb Outside Lobby A106	
82	Locker Room A104 (Above Shw Entrance Door)		HWR Bal Valve Shw Room A104A	
83	Locker Room A104 (Above Shw Entrance Door)		HWR Drain for Shw Room A104A	
84	Room A103 (Above Mixing Valve)		Hot Supply Mixing Valve Shower	

VAVLE IDENTIFICATION CHART FOR PLUMBING			SYSTEM
Job Name: AMES FIELD - STADIUM		Installed by: Industrial Maintenance & Mechanical Contractors, Inc.	
Date:			
Valve No.	Location	Size	Purpose
85	Room A103 (Above Mixing Valve)		Cold Supply Mixing Valve Shower Room A104A
86	Room A104 (Overhead Between Island & Office Wall)		Cold Supply Lavs & Drk. Ptn Room A104
87	Room A104A (Overhead Between Island & Office Wall)		HWR Drain Lavs Room A104A
88	Room A104A (Overhead Between Island & Office Wall)		Hot Supply for Lavs Room A104A
89	Room A104A (Overhead Between Island & Office Wall)		Cold Supply to WCs Outside Hose Bib Room A104
90	Room A103 (Above South Wall)		Cold Supply Urinals Room A104
91	Room A117 (In Chase Behind WCs)		Cold Water Drain for WCs Room A117
92	Locker Room A104 (Behind Access Panel Under Drk Fountain)		Hot Water Drain Lavs Room A104
93	Locker Room A104 (In Chase Behind WCs)		Cold Drain WCs Room A104
94	Mezz. Room B112 (North Wall)		Cold Supply to Mezz. Room B112
95	Mezz. Room B112 (North Wall)		Cold Supply Water Heater Room B112
96	Mezz. Room B112 (North Wall)		Cold Supply Mixing Valve Room B112
97	Mezz. Room B112 (North Wall)		Cold Supply Water Heater B112
98	Mezz. Room B112 (North Wall)		Hot From Heater (Circ. Pump Inlet)
99	Mezz. Room B112 (North Wall)		Hot From Heater (Circ. Pump Outlet)
100	Mezz. Room B112 (North Wall)		HWR Bal Valve (Circ. Pump Inlet)
101	Mezz. Room B112 (North Wall)		HWR Bal Valve (Circ. Pump Outlet)
102	Mezz. Room B112 (North Wall)		HWR Drain
103	Mezz. Room B112 (North Wall)		HWR Drain
104	Mezz. Room B112 (North Wall)		HWR Drain
105	Mezz. Room B112 (North Wall)		Hot Water Drain
106	Mezz. Room B112 (North Wall)		Cold Water Drain
107	Mezz. Room B112 (North Wall)		Hot Water Storage Tank Drain
108	Mechanical Room A120		Irrigation Pump Isolation Valve
109	Mechanical Room A120		Irrigation Pump Blowoff Valve

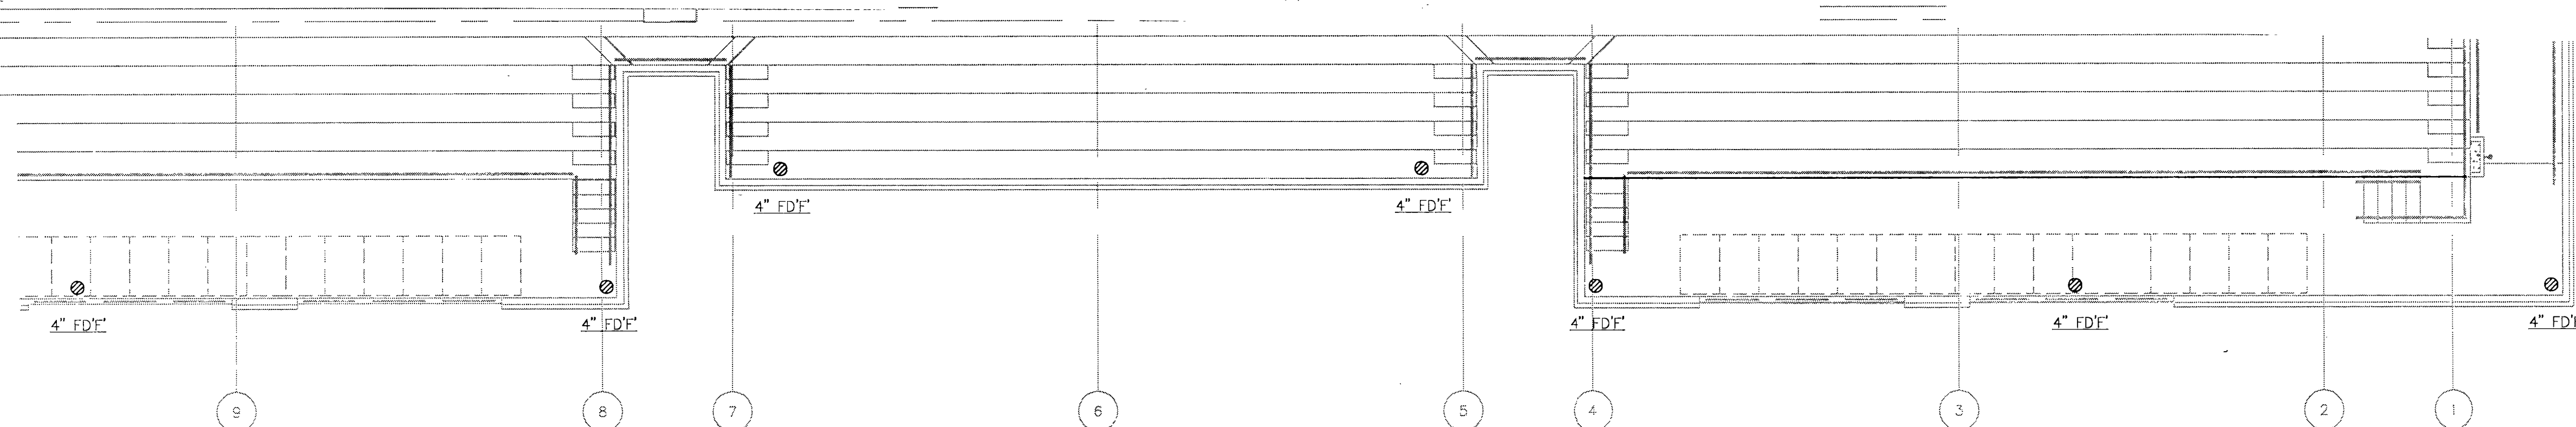


FOOTBALL STADIUM SEATING PLAN
SCALE: 1/8" = 1'-0"

PLUMBING PLAN NOTES


- 3/4" CW DROP.
- 3/4" CW DROP. 1 1/2" V RISE. 3" W DN.
- 3/4" HWR DROP. CONNECT TO HOT WATER SUPPLY AFTER LAST LAV CONNECTION.
- 1" CW DROP. 1" HWR DROP.
- 2" V RISE. 3" W DN.
- 1" HWR DROP.
- 2" CW DROP. PROVIDE WHA 'C' ON CW BRANCH BEFORE LAST FIXTURE CONNECTION.
- 2" V RISE. 4" W DN.
- WATER HEATER (WH-1). 1" GAS DROP TO WATER HEATER. SEE DETAIL ON DRAWING P532.
- 2 1/2" CW DROP. SEE DETAIL OF BACKFLOW PREVENTER PIPING DIAGRAM ON DRAWING P532.
- 1" V. BACKFLOW PREVENTER (BFP-3) BELOW.
- 4" V UP. 4" W DN. 4" V.T.R.
- 2" CW DROP. PROVIDE WHA 'D' ON CW BRANCH BEFORE LAST FIXTURE CONNECTION.
- 2 1/2" CW. 1 1/2" HWR. 3/4" HWR.
- 2 1/2" INCOMING WATER SERVICE. SEE DRAWING P202 FOR CONTINUATION.
- 1 1/4" INCOMING GAS SERVICE UP THRU FLOOR WITH GBR-2 ON RISER. 1 1/4" GAS RISE AFTER GBR-2. SEE DRAWING P202 FOR CONTINUATION.

GENERAL PLUMBING PLAN NOTES

- SLOPE ALL DOMESTIC WATER PIPING TO ALLOW FOR OFF-SEASON DRAIN DOWN.
- IN OFF-SEASON PERIODS WHEN THE HEATING SYSTEMS ARE TURNED OFF AND ALL DOMESTIC WATER LINES ARE DRAINED, ALL FLUSH VALVE FIXTURES SHALL BE FLUSHED AND ALL PLUMBING FIXTURE TRAPS SHALL BE FILLED WITH ANTI-FREEZE.

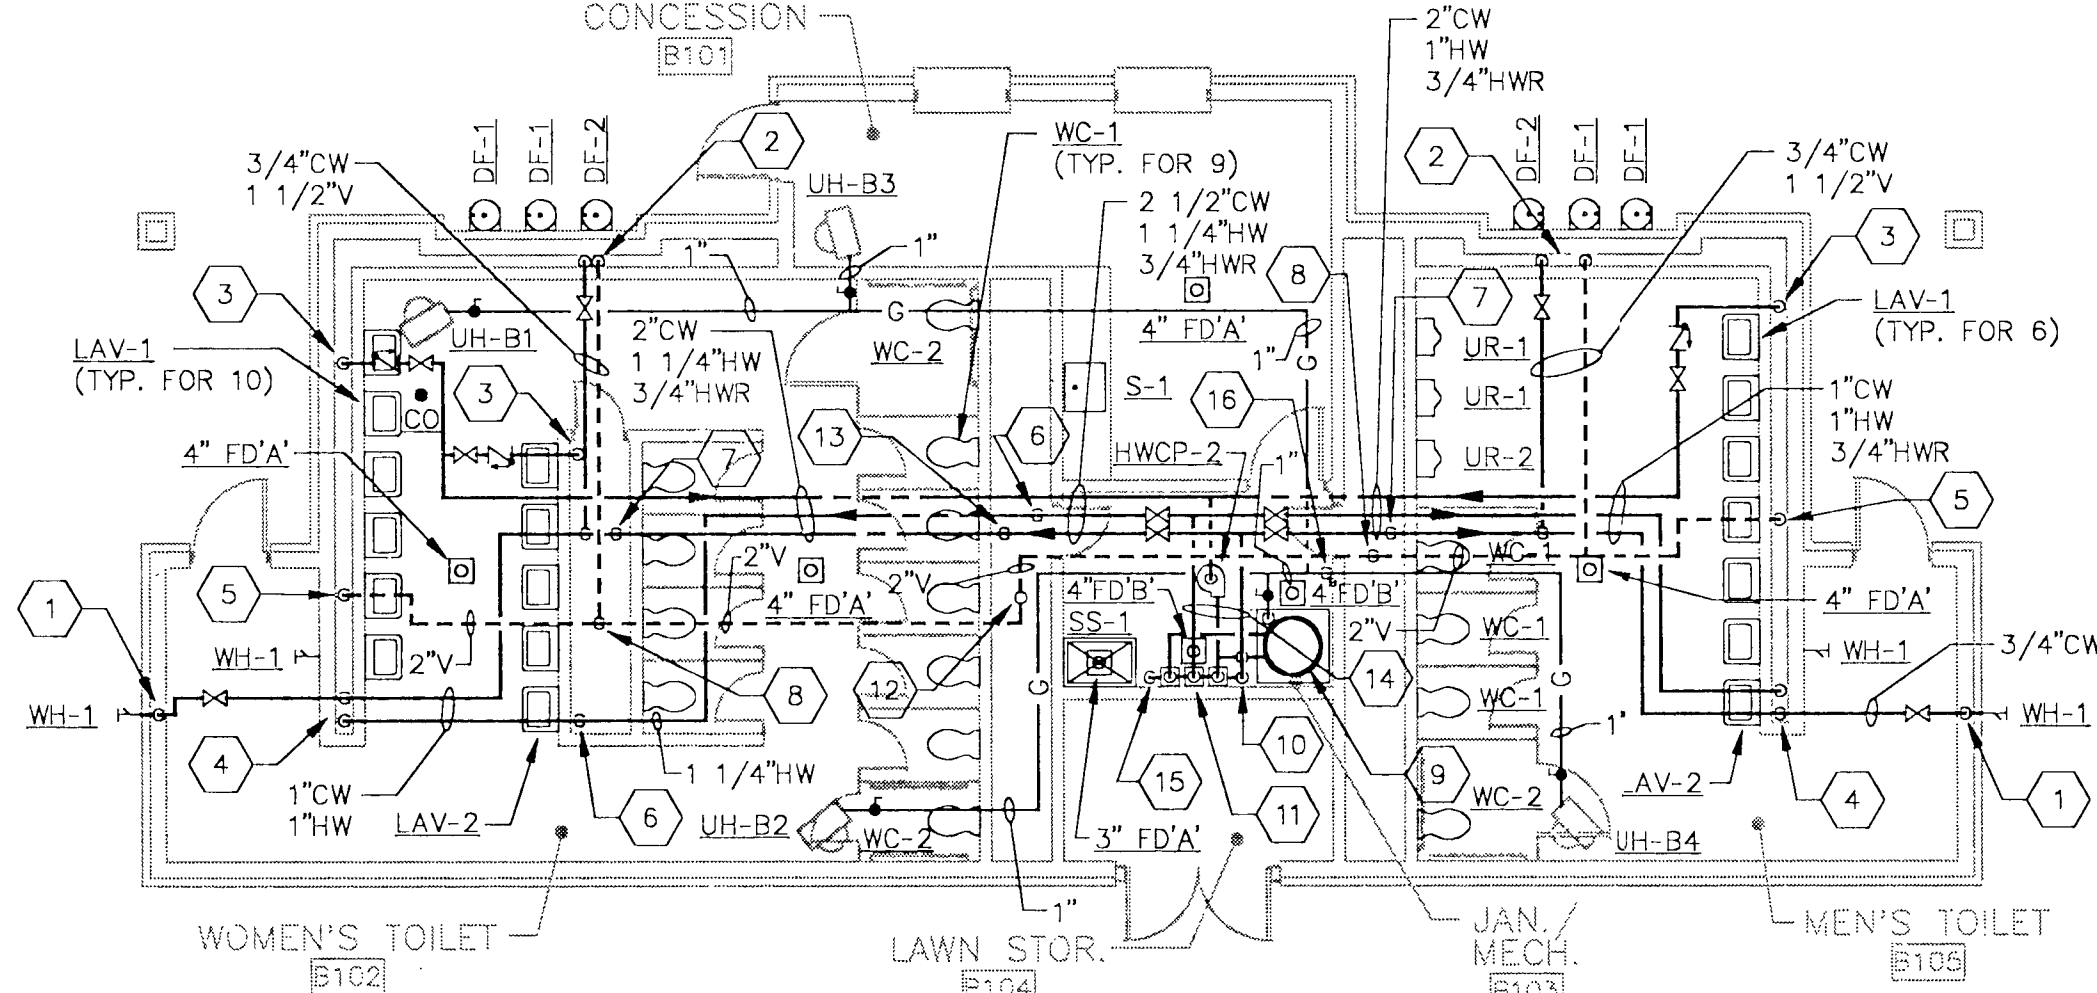

PLUMBING VISITOR TOILET AND CONCESSION FLOOR PLAN
SCALE: 1/8" = 1'-0"

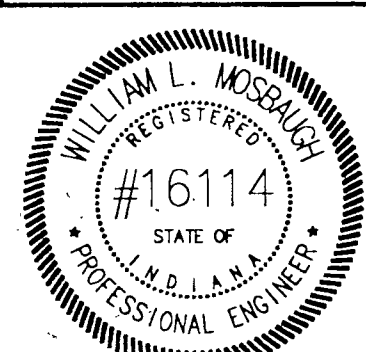

CERTIFIED


THE ODLE MCGUIRE & SHOOK CORPORATION
ARCHITECTURE • ENGINEERING • LANDSCAPE ARCHITECTURE • INTERIOR DESIGN
6765 NORTH STATE ROAD 37, POST OFFICE BOX 2149, BLOOMINGTON, INDIANA 47402, 812/876-2020
8275 ALISON POINTE TRAIL, POST OFFICE BOX 50426, INDIANAPOLIS, INDIANA 46250, 317/842-0000

REVISIONS


MICHIGAN CITY SPORTS COMPLEX
AMES FIELD
MICHIGAN CITY, INDIANA

PROJECT NO: 93052
DATE: MAY 31, 1994
drawn by: PJD
checked by: WLM


P204
PLUMBING VISITOR TOILET AND CONCESSION FLOOR PLAN

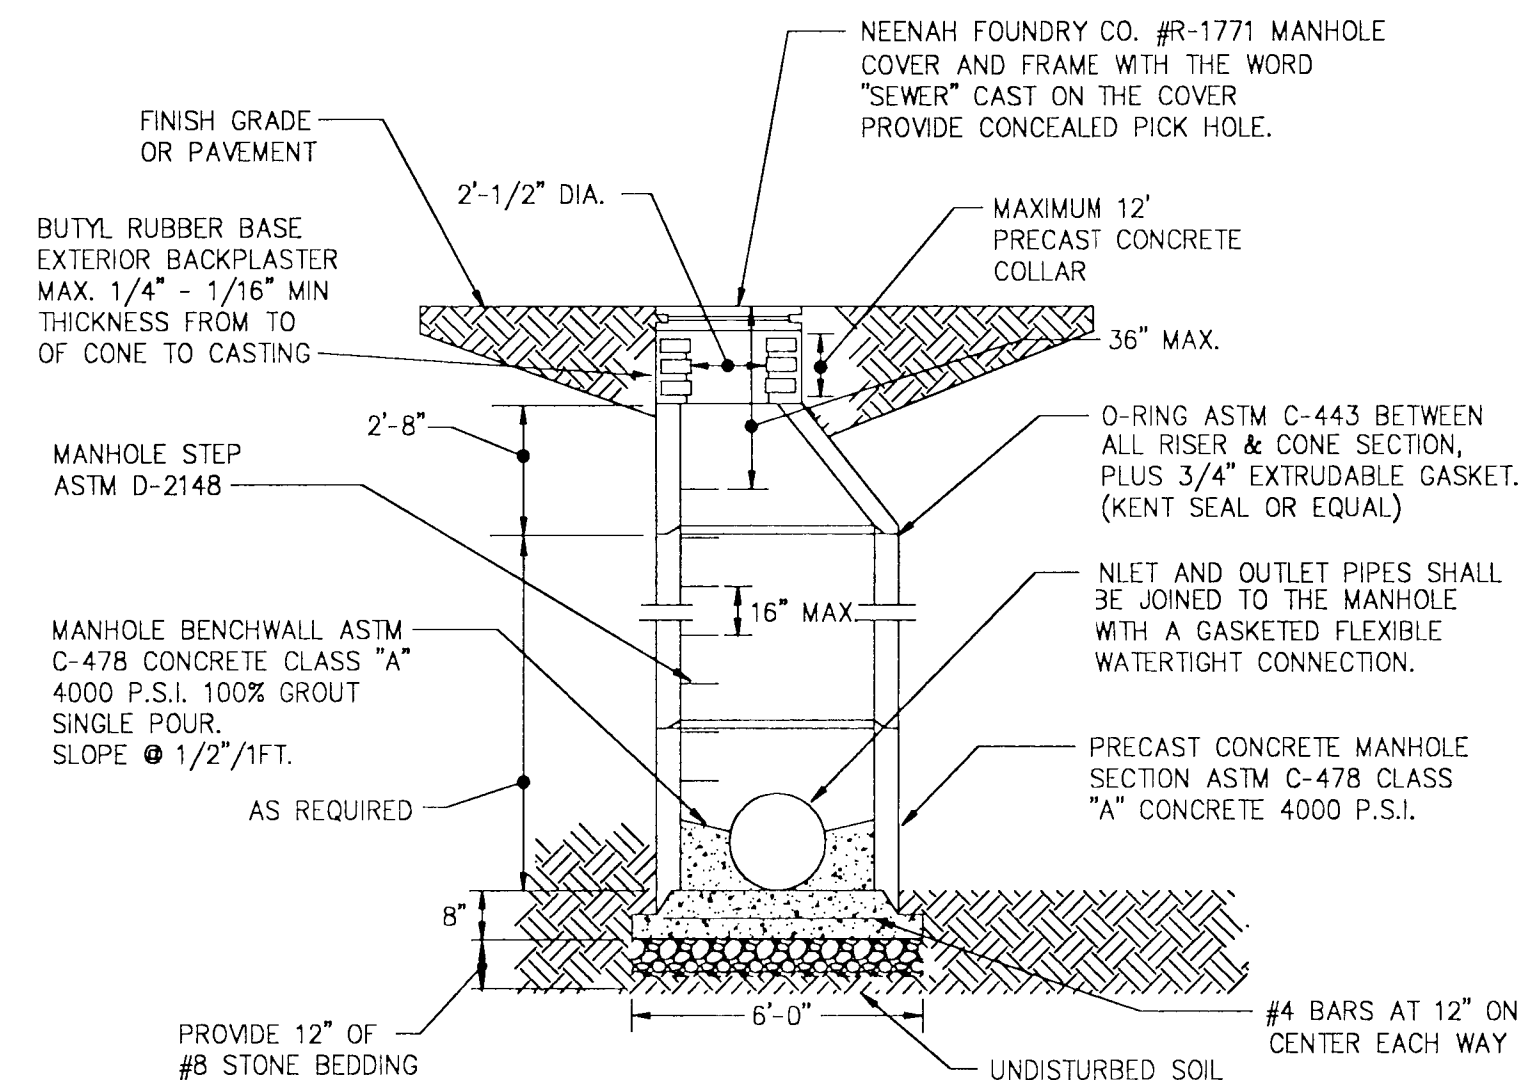


SANITARY MANHOLE
NO SCALE

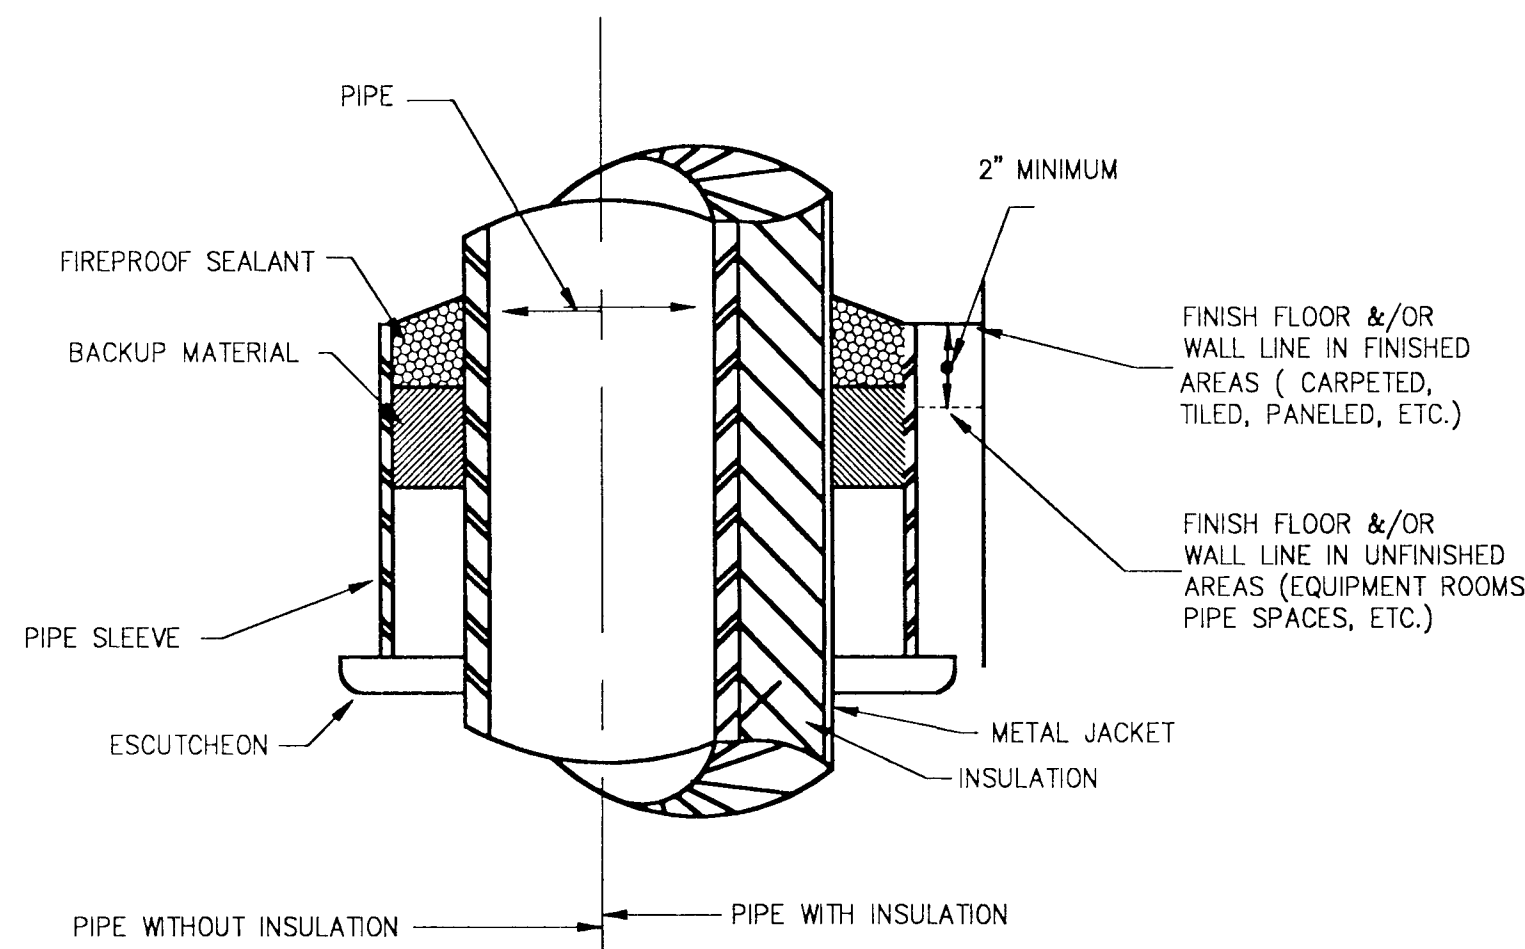


PIPE SLEEVE THRU FLOOR &/OR WALL
NO SCALE

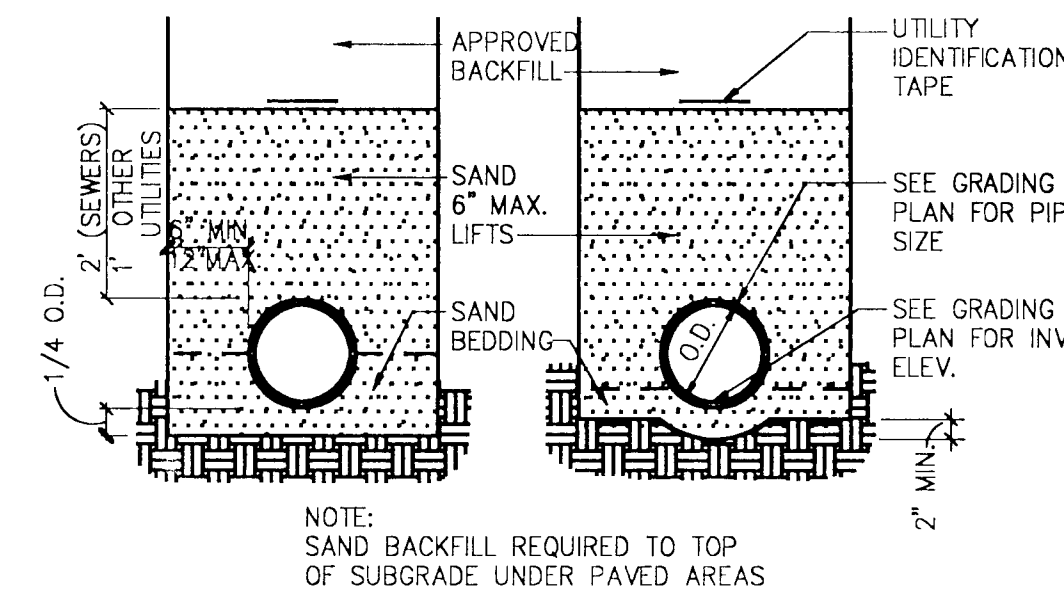


PIPE BEDDING AND BACKFILL DETAIL
NO SCALE

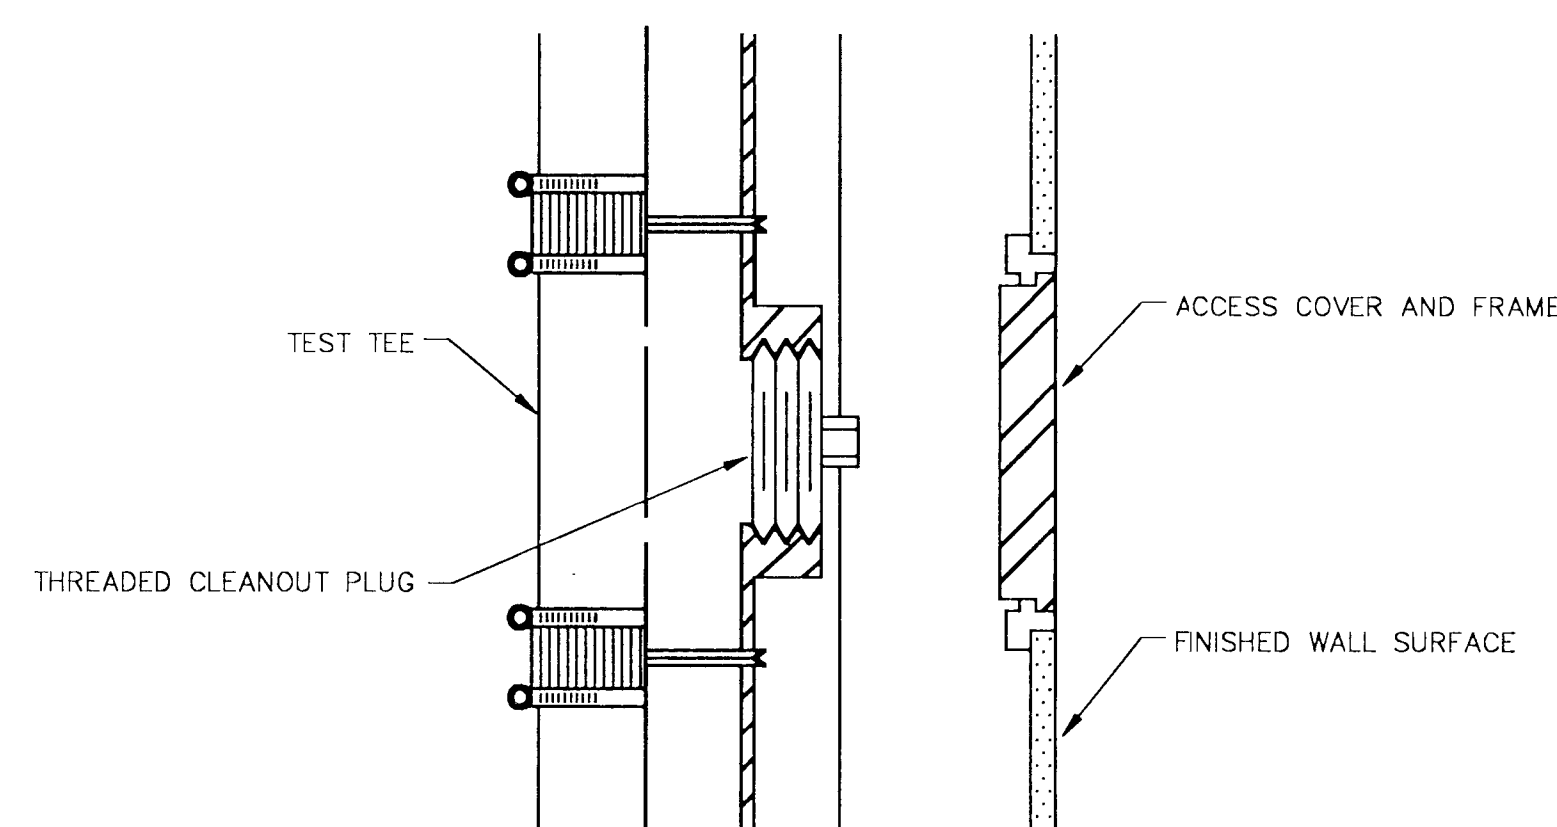


NO HUB W/ACCESS DOOR DETAIL
NO SCALE

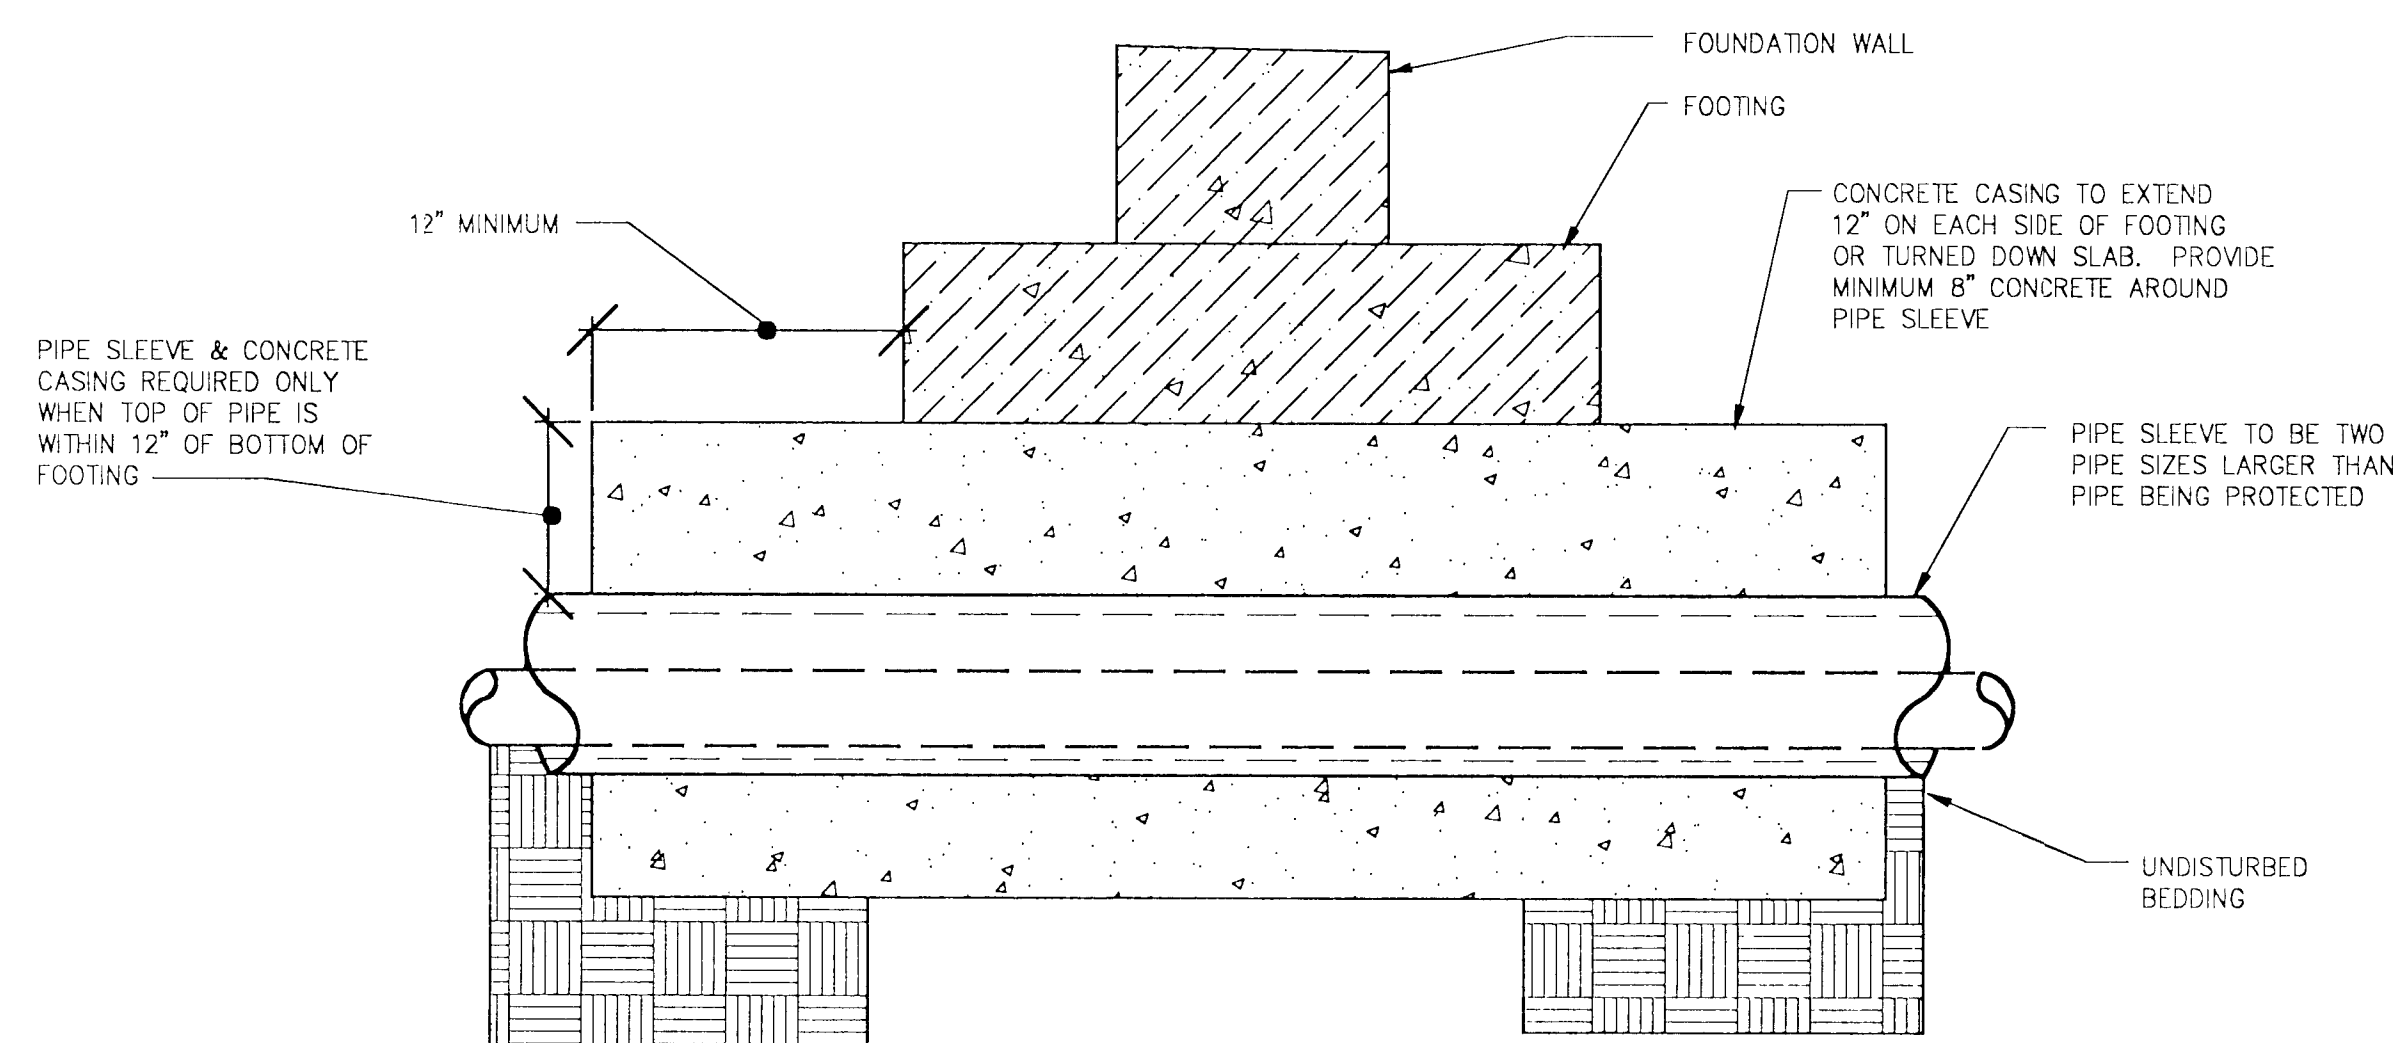


PIPE SLEEVE BELOW FOOTING OR TURNED DOWN SLAB
NO SCALE

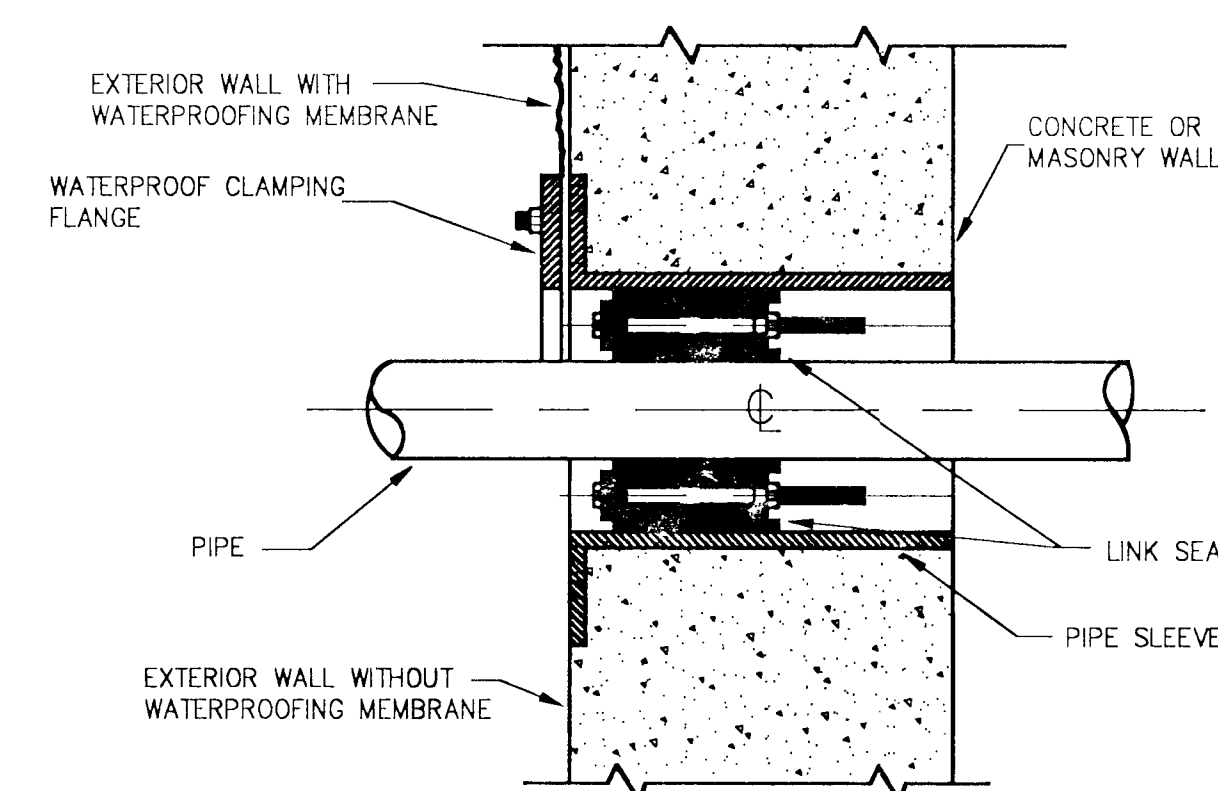

PIPE SLEEVE THRU EXTERIOR WALL OR FOUNDATION WALL (BELOW GRADE)
NO SCALE

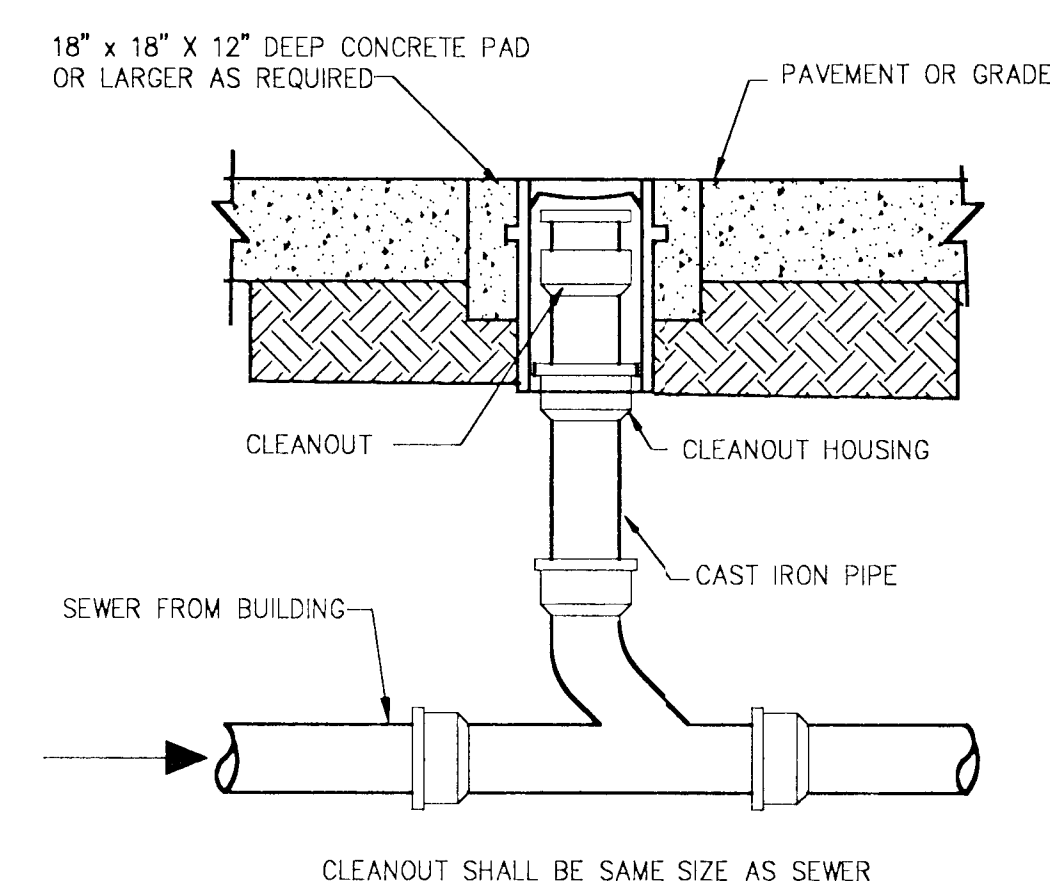

EXTERIOR CLEANOUT DETAIL
NO SCALE

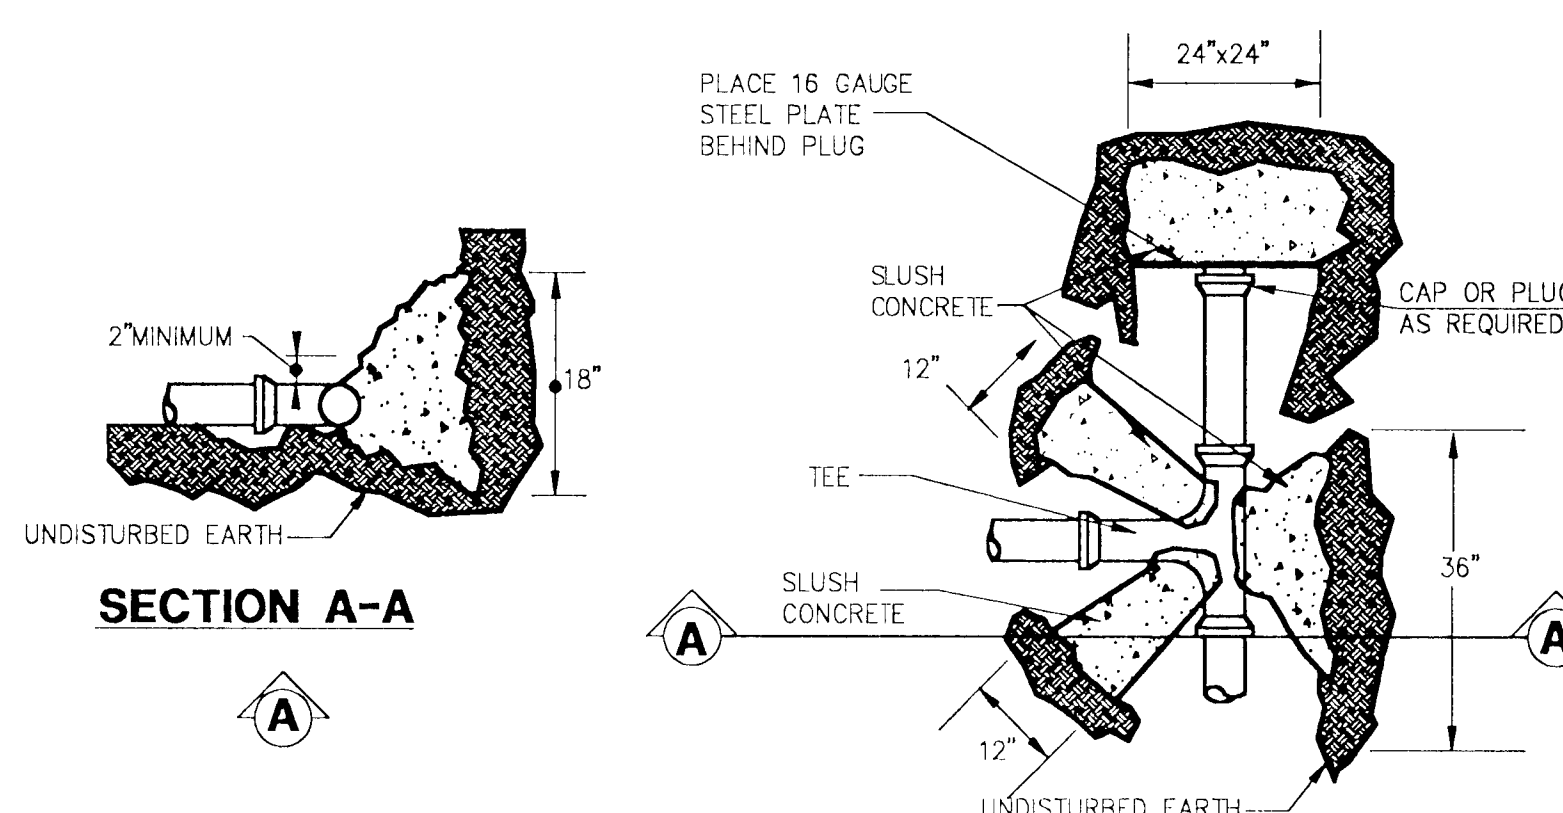

BURIED WATERMAIN SUPPORT DETAIL
NO SCALE

PLUMBING EQUIPMENT SCHEDULE

MARK	ITEM	LOCATION	CAPACITY	MANUFACTURER AND MODEL	ELECTRICAL LOAD					REMARKS
					HP	RPM	VOLTS	AMPS	PHASE	
DWH-1	DOMESTIC WATER HEATER WITH STORAGE TANK	MEZZANNE B112	650,000 BTU INPUT, RECOVERY 870 GPH @ 100' RISE W/VERTICAL 1250 GALLON STORAGE TANK	LOCHVAR COPPER-FIN II PACKAGED SYSTEM #PU-CF0650-PM	-	-	120	18	1	
DWH-2	DOMESTIC WATER HEATER	JAN./MECH. B103	88,000 BTU INPUT, RECOVERY 85 GPH @ 100' RISE WITH 100 GALLON STORAGE TANK	LOCHVAR CNR090-100	-	-	-	-	-	
HWCP-1	HOT WATER CIRC. PUMP	MEZZANNE B112	6 GPM @ 3.0 TDH	GRUNDFOS #UPS15-42F	1/25	350	115	.40	1	PROVIDE AQUASTAT PUMP CONTROLLER
HWCP-2	HOT WATER CIRC. PUMP	JAN./MECH. B103	2 GPM @ 1.0 TDH	GRUNDFOS #UPS15-42F	1/25	350	115	.40	1	PROVIDE AQUASTAT PUMP CONTROLLER
TMV-1	THERMOSTATIC MIXING VALVE	MEZZANNE B112	57 GPM @ 21 PSI PRESSURE DIFFERENTIAL	POWERS #595-WM-100-M-C-08-D-I-03	-	-	-	-	-	MOUNT ON WALL @ 56" A.F.F.
TMV-2	THERMOSTATIC MIXING VALVE	JAN./MECH. B103	21 GPM @ 25 PSI PRESSURE DIFFERENTIAL	POWERS #595-WM-050-M-C-08-D-I-03	-	-	-	-	-	MOUNT ON WALL @ 56" A.F.F.
TMV-3	THERMOSTATIC MIXING VALVE	OFFICE A103	40 GPM @ 11 PSI PRESSURE DIFFERENTIAL	POWERS #432-A-D-P-S-O SEMI-RECESSED	-	-	-	-	-	MOUNT ON WALL @ 42" A.F.F.
TMV-4	THERMOSTATIC MIXING VALVE	OFFICE A118	40 GPM @ 11 PSI PRESSURE DIFFERENTIAL	POWERS #432-A-D-P-S-O SEMI-RECESSED	-	-	-	-	-	MOUNT ON WALL @ 42" A.F.F.
ET-1	EXPANSION TANK	MEZZANNE B112	TOTAL VOL. 77 GAL. MAX. ACCEPT. VOL. 36 GAL.	EXTROL AST-180	-	-	-	-	-	
GPR-1	GAS PRESSURE REGULATOR	MECH. A120	2,585 MBH INPUT FROM 2 PSIG TO 14" W.C.	FISHER #S-133L	-	-	-	-	-	
GPR-2	GAS PRESSURE REGULATOR	JAN./MECH. B103	492 MBH INPUT FROM 2 PSIG TO 14" W.C.	FISHER #S-133L	-	-	-	-	-	
BFP-1	BACKFLOW PREVENTER	MECH. A120	156 GPM W/12 PSI DROP	WATTS 3"-SERIES 909-QT-S	-	-	-	-	-	
BFP-2	BACKFLOW PREVENTER	MECH. A120	55 GPM W/10.5 PSI DROP	WATTS 2"-SERIES 909-QT-S	-	-	-	-	-	
BFP-3	BACKFLOW PREVENTER	JAN./MECH. B103	91 GPM W/11.5 PSI DROP	WATTS 2"-SERIES 909-QT-S	-	-	-	-	-	

WATER HAMMER ARRESTER SCHEDULE

MARK	I.P.S.	F.U. RATING	J.R. SMITH No.	WADE No.	ZURN No.	REMARKS
(A)	3/4"	1 - 11	5005	W - 5	100	P.D.I. CERTIFIED
(B)	1"	12 - 32	5010	W - 10	200	P.D.I. CERTIFIED
(C)	1"	33 - 60	5020	W - 20	300	P.D.I. CERTIFIED
(D)	1"	61 - 113	5030	W - 50	400	P.D.I. CERTIFIED
(E)	1"	114 - 154	5040	W - 75	500	P.D.I. CERTIFIED

PLUMBING FIXTURE SCHEDULE

"P" No.	FIXTURE NAME	TRAP SIZE	ROUGH IN SIZE W	V	SIZE CW	HW	MOUNTING HEIGHT	REMARKS
WC-1	WATER CLOSET, WALL MTD. W/FLUSH VALVE	4"	4"	2"	1"	-	15"	
WC-2	WATER CLOSET, WALL MTD. W/FLUSH VALVE	4"	4"	2"	1"	-	18"	HANDICAP
UR-1	URINAL, WALL MOUNTED W/FLUSH VALVE	2"	2"	1 1/2"	3/4"	-	24"	
UR-2	URINAL, WALL MOUNTED W/FLUSH VALVE	2"	2"	1 1/2"	1"	-	17"	HANDICAP
LAV-1	LAVATORY, WALL MOUNTED	1 1/2"	1 1/2"	1 1/2"	1 1/2"	-	32"	
LAV-2	LAVATORY, WALL MOUNTED	1 1/2"	1 1/2"	1 1/2"	1 1/2"	-	34"	HANDICAP
S-1	STAINLESS STEEL SINK	1 1/2"	1 1/2"	1 1/2"	1 1/2"	-		
SH-1	SHOWER	-	-	-	3/4"	3/4"	HEAD @ 72"	
SH-2	SHOWER PANEL	-	-	-	3/4"	3/4"	HEAD @ 72"	
DF-1	DRINKING FOUNTAIN	1 1/4"	1 1/2"	1 1/2"	1 1/2"	-	40" TO SPOUT	
DF-2	DRINKING FOUNTAIN	1 1/4"	1 1/2"	1 1/2"	1 1/2"	-	36" TO SPOUT	HANDICAP
DF-3	DRINKING FOUNTAIN	1 1/4"	1 1/2"	1 1/2"	1 1/2"	-	40" TO SPOUT	
DF-4	DRINKING FOUNTAIN	1 1/4"	1 1/2"	1 1/2"	1 1/2"	-	36" TO SPOUT	HANDICAP
MB-1	MOP BASIN	3"	3"	2"	3/4"	3/4"	-	
HB-1	HOSE BIBB	-	-	-	3/4"	-	18" A.F.G.	
WH-1	WALL HYDRANT	-	-	-	3/4"	-	18" A.F.G.	

GENERAL PLUMBING NOTES

ALL PLUMBING INSTALLATIONS AND MATERIAL SHALL BE IN STRICT ACCORDANCE WITH ALL LOCAL, STATE AND FEDERAL CODES AND REGULATIONS AND AUTHORITIES HAVING JURISDICTION OVER THIS PROJECT.

ALL TRANSITIONS OF PIPE FROM ONE MATERIAL TO ANOTHER SHALL BE MADE WITH THE APPROPRIATE FITTING, ADAPTORS AND SEALANTS.

NO WASTE OR DRAINAGE PIPING LOCATED UNDERGROUND BELOW FINISH GRADE SHALL BE LESS THAN 2" IN SIZE.

PLUMBING CONTRACTOR SHALL BE RESPONSIBLE FOR THE INSTALLATION OF ALL TRAPS, FITTINGS AND CLEANOUTS WITHIN THE BUILDING AS REQUIRED BY CODE.

WHEREVER VALVES ARE SHOWN AND/OR REQUIRED PLUMBING CONTRACTOR SHALL PROVIDE AND INSTALL APPROVED ACCESS PANELS.

PLUMBING CONTRACTOR SHALL COORDINATE ROUGH-IN REQUIREMENTS FOR ALL EQUIPMENT WITH EQUIPMENT MANUFACTURER AND OWNER PRIOR TO START OF PROJECT.

ALL HOT WATER, HOT WATER RETURN AND COLD WATER LINES SHALL BE INSULATED WITH APPROVED INSULATION.

FLEXIBLE WATER PIPING SHALL BE USED WHERE WATER LINES CROSS SEISMIC JOINTS.

SLOPE ALL DOMESTIC WATER PIPING TO ALLOW FOR OFF-SEASON DRAIN DOWN.

IN OFF-SEASON PERIODS WHEN THE HEATING SYSTEMS ARE TURNED OFF AND ALL DOMESTIC WATER LINES ARE DRAINED, ALL FLUSH VALVE FIXTURES SHALL BE FLUSHED AND ALL PLUMBING FIXTURE TRAPS SHALL BE FILLED WITH ANTI-FREEZE.



CERTIFIED
William L. McCuire

THE ODLE MCCUIRE & SHOOK CORPORATION
ARCHITECTURE • ENGINEERING • LANDSCAPE ARCHITECTURE • INTERIOR DESIGN
6765 NORTH STATE ROAD 37, POST OFFICE BOX 2149, BLOOMINGTON, INDIANA 47402, 812/876-7020
8275 ALLISON PONTE TRAIL, POST OFFICE BOX 50426, INDIANAPOLIS, INDIANA 46250, 317/842-0000

REVISIONS


Copyright 1994 by THE ODLE MCCUIRE & SHOOK CORPORATION. Copyright includes architectural work, building design, plans or drawings, and specifications. Architectural work is the confidential property of the corporation and shall remain the property of the corporation. No part of this document may be reproduced without written permission. A prohibition is prohibited.

MICHIGAN CITY SPORTS COMPLEX
AMES FIELD
MICHIGAN CITY, INDIANA


PROJECT NO. 93052
DATE: MAY 31, 1994
drawn by: PJD
checked by: WLM

P501
PLUMBING SCHEDULES
AND DETAILS

F:\ELECT\93052\0302E101 05-31-94 8:59:31

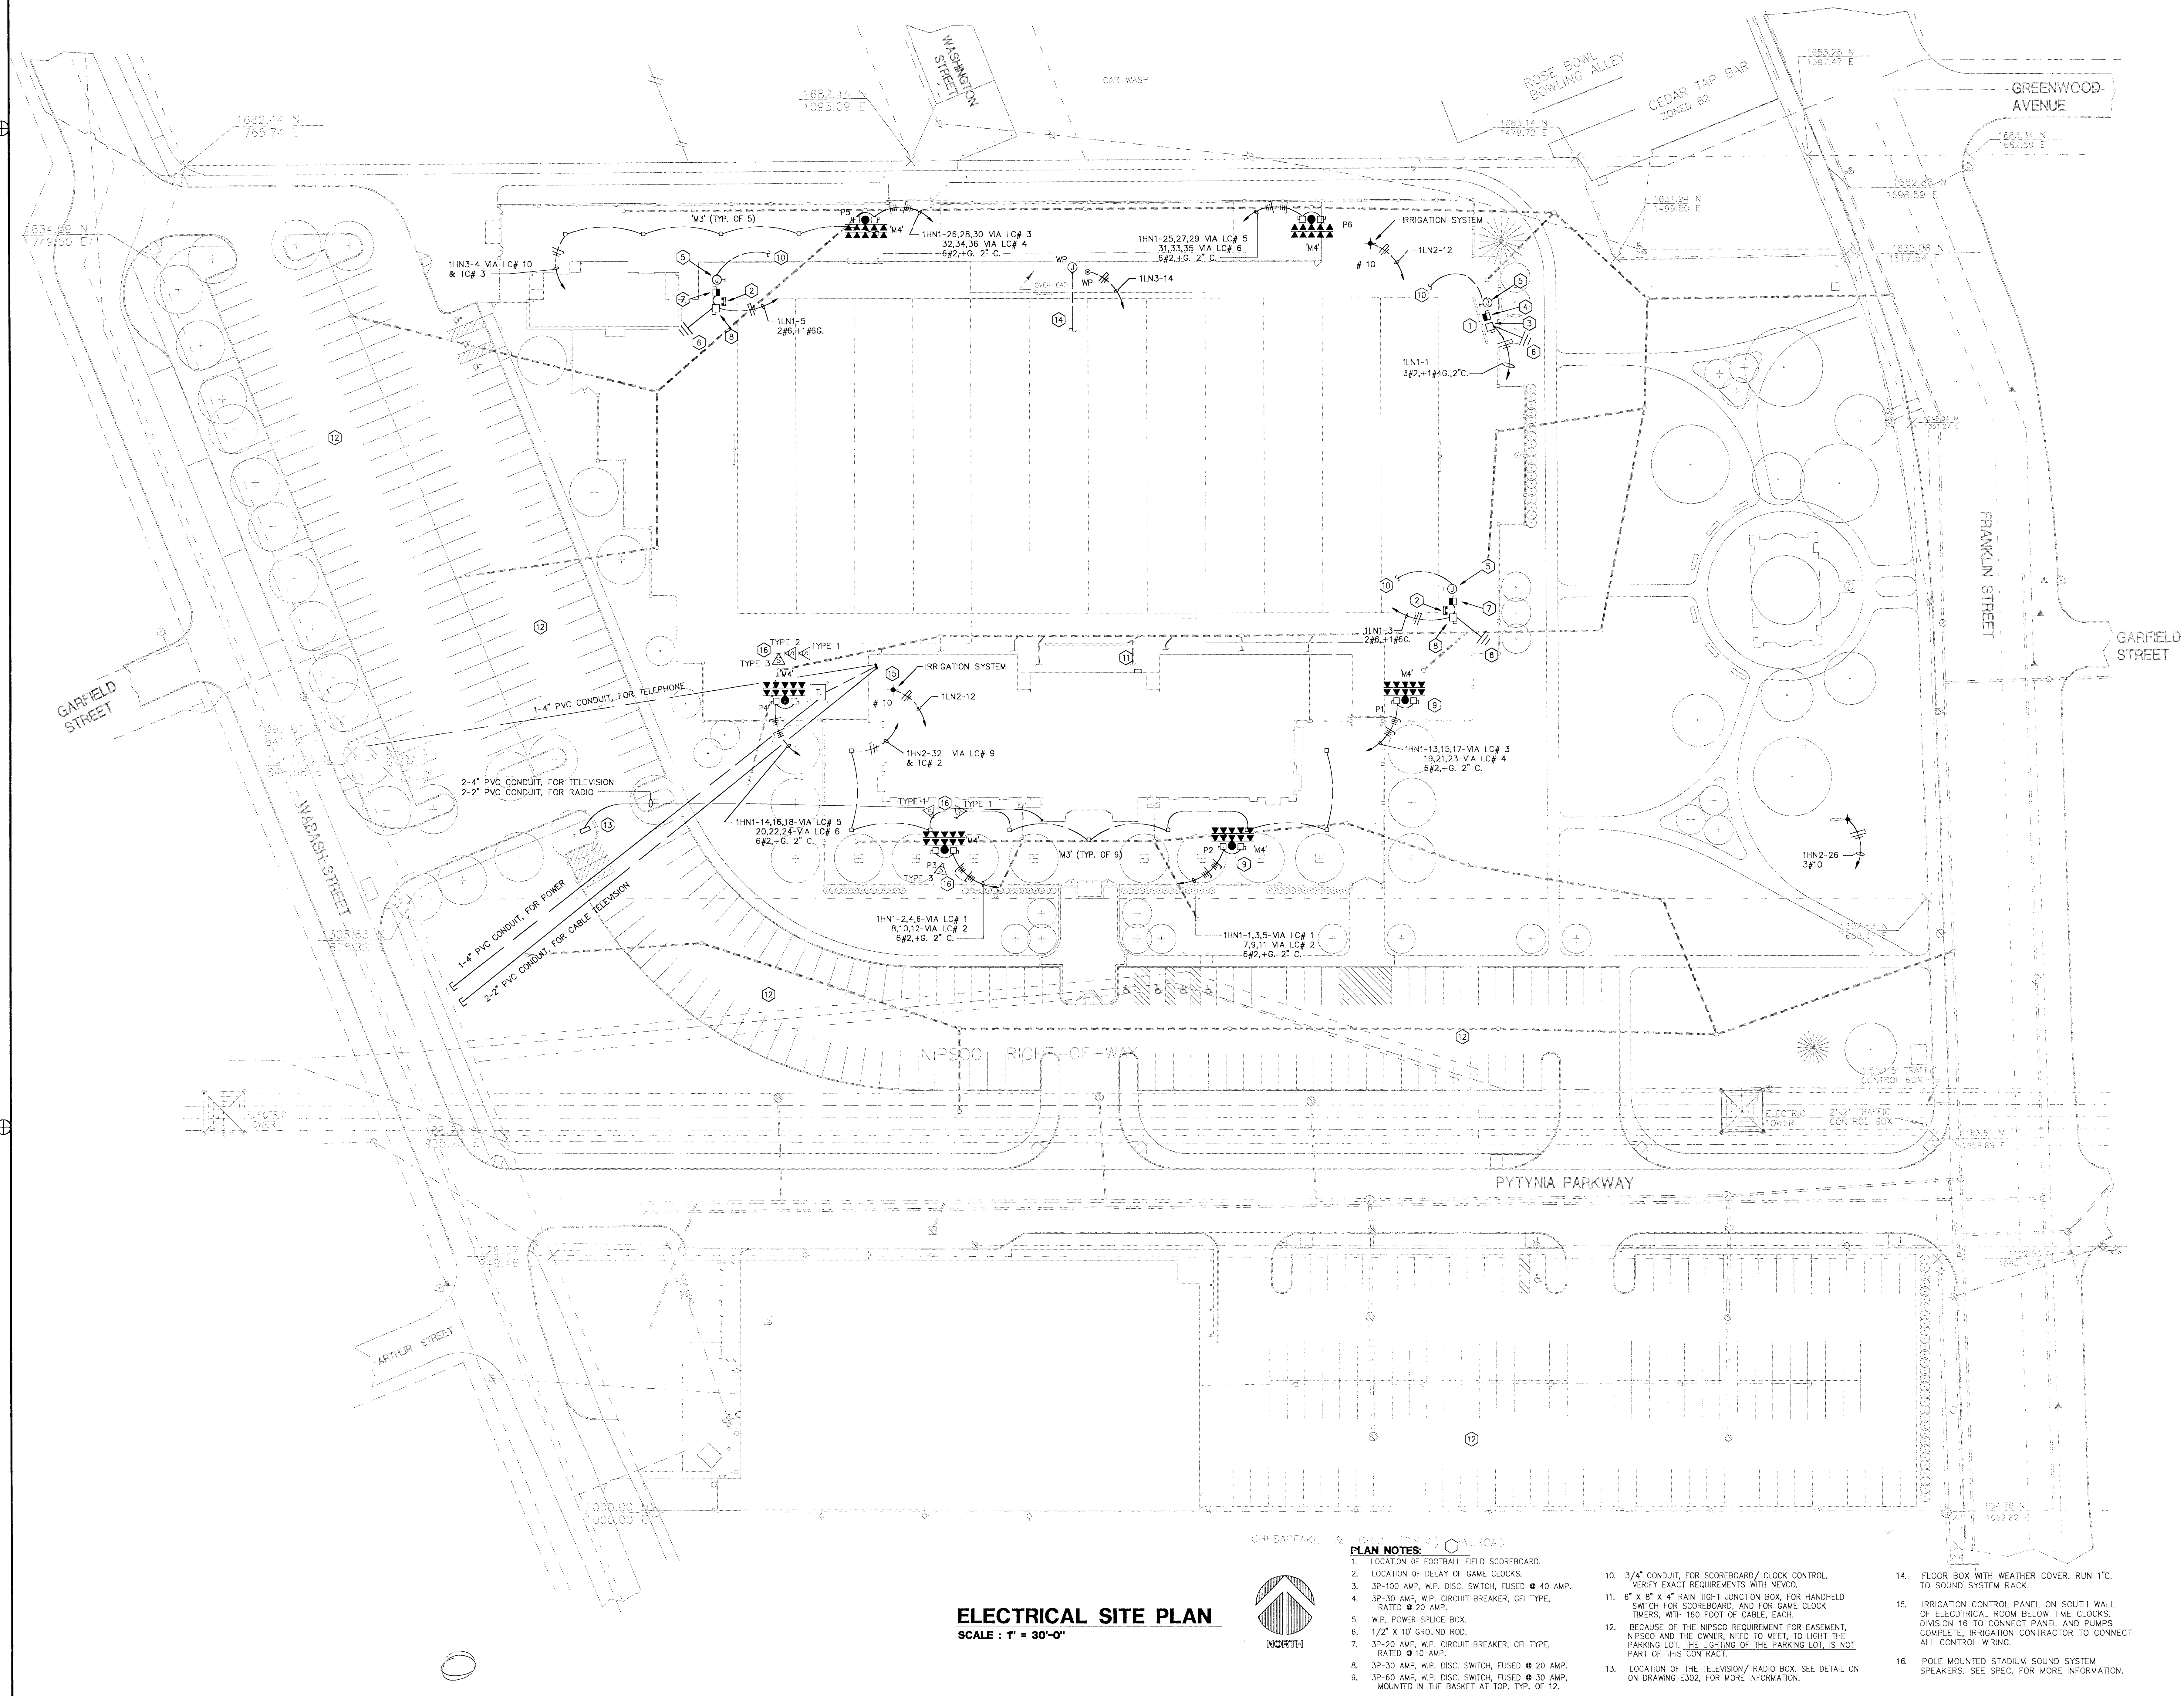

ELECTRICAL SITE PLAN
SCALE: 1" = 30'-0"

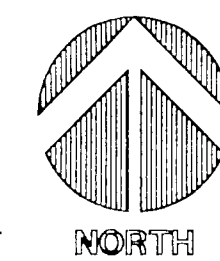

PLAN NOTES:

1. LOCATION OF FOOTBALL FIELD SCOREBOARD.
2. LOCATION OF DELAY OF GAME CLOCKS.
3. 3P-100 AMP, W.P. DISC. SWITCH, FUSED @ 40 AMP.
4. 3P-30 AMP, W.P. CIRCUIT BREAKER, GFI TYPE, RATED @ 20 AMP.
5. W.P. POWER SPICE BOX.
6. 1/2" X 10' GROUND ROD.
7. 3P-20 AMP, W.P. CIRCUIT BREAKER, GFI TYPE, RATED @ 10 AMP.
8. 3P-30 AMP, W.P. DISC. SWITCH, FUSED @ 20 AMP.
9. 3P-60 AMP, W.P. DISC. SWITCH, FUSED @ 30 AMP, MOUNTED IN THE BASKET AT TOP, TYP. OF 12.
10. 3/4" CONDUIT, FOR SCOREBOARD/ CLOCK CONTROL. VERIFY EXACT REQUIREMENTS WITH NEVCO.
11. 6" X 8" X 4" RAIN TIGHT JUNCTION BOX, FOR HANDHELD SWITCH FOR SCOREBOARD, AND FOR GAME CLOCK TIMERS, WITH 160 FOOT OF CABLE, EACH.
12. BECAUSE OF THE NIPSCO REQUIREMENT FOR EASEMENT, NIPSCO AND THE OWNER, NEED TO MEET, TO LIGHT THE PARKING LOT, THE LIGHTING OF THE PARKING LOT IS NOT PART OF THIS CONTRACT.
13. LOCATION OF THE TELEVISION/ RADIO BOX. SEE DETAIL ON ON DRAWING E302, FOR MORE INFORMATION.
14. FLOOR BOX WITH WEATHER COVER. RUN 1" C. TO SOUND SYSTEM RACK.
15. IRRIGATION CONTROL PANEL ON SOUTH WALL OF ELECTRICAL ROOM BELOW TIME CLOCKS. DIVISION 16 TO CONNECT PANEL AND PUMPS COMPLETE, IRRIGATION CONTRACTOR TO CONNECT ALL CONTROL WIRING.
16. POLE MOUNTED STADIUM SOUND SYSTEM SPEAKERS. SEE SPEC. FOR MORE INFORMATION.



CERTIFIED
William McQuire

THE ODLE MCQUIRE & SHOOK CORPORATION
ARCHITECTURE • ENGINEERING • LANDSCAPE ARCHITECTURE • INTERIOR DESIGN
6765 NORTH STATE ROAD 37, POST OFFICE BOX 2149, BLOOMINGTON, INDIANA 47402, 812/876-2020
8275 ALISON POINTE TRAIL, POST OFFICE BOX 50428, INDIANAPOLIS, INDIANA 46250, 317/842-0000


REVISIONS

© Copyright 1994 by THE ODLE MCQUIRE & SHOOK CORPORATION. Copyright includes architectural work, building design, plans or drawings, and specifications. Architectural work is the overall form as well as the arrangement and composition of space and elements in the design. Reproduction without written permission is prohibited.



MICHIGAN CITY SPORTS COMPLEX
AMES FIELD
MICHIGAN CITY, INDIANA

PROJECT NO. 93052
DATE MAY 31, 1994
drawn by: JJC/ KWB
checked by: RSB



E101
ELECTRICAL
SITE PLAN

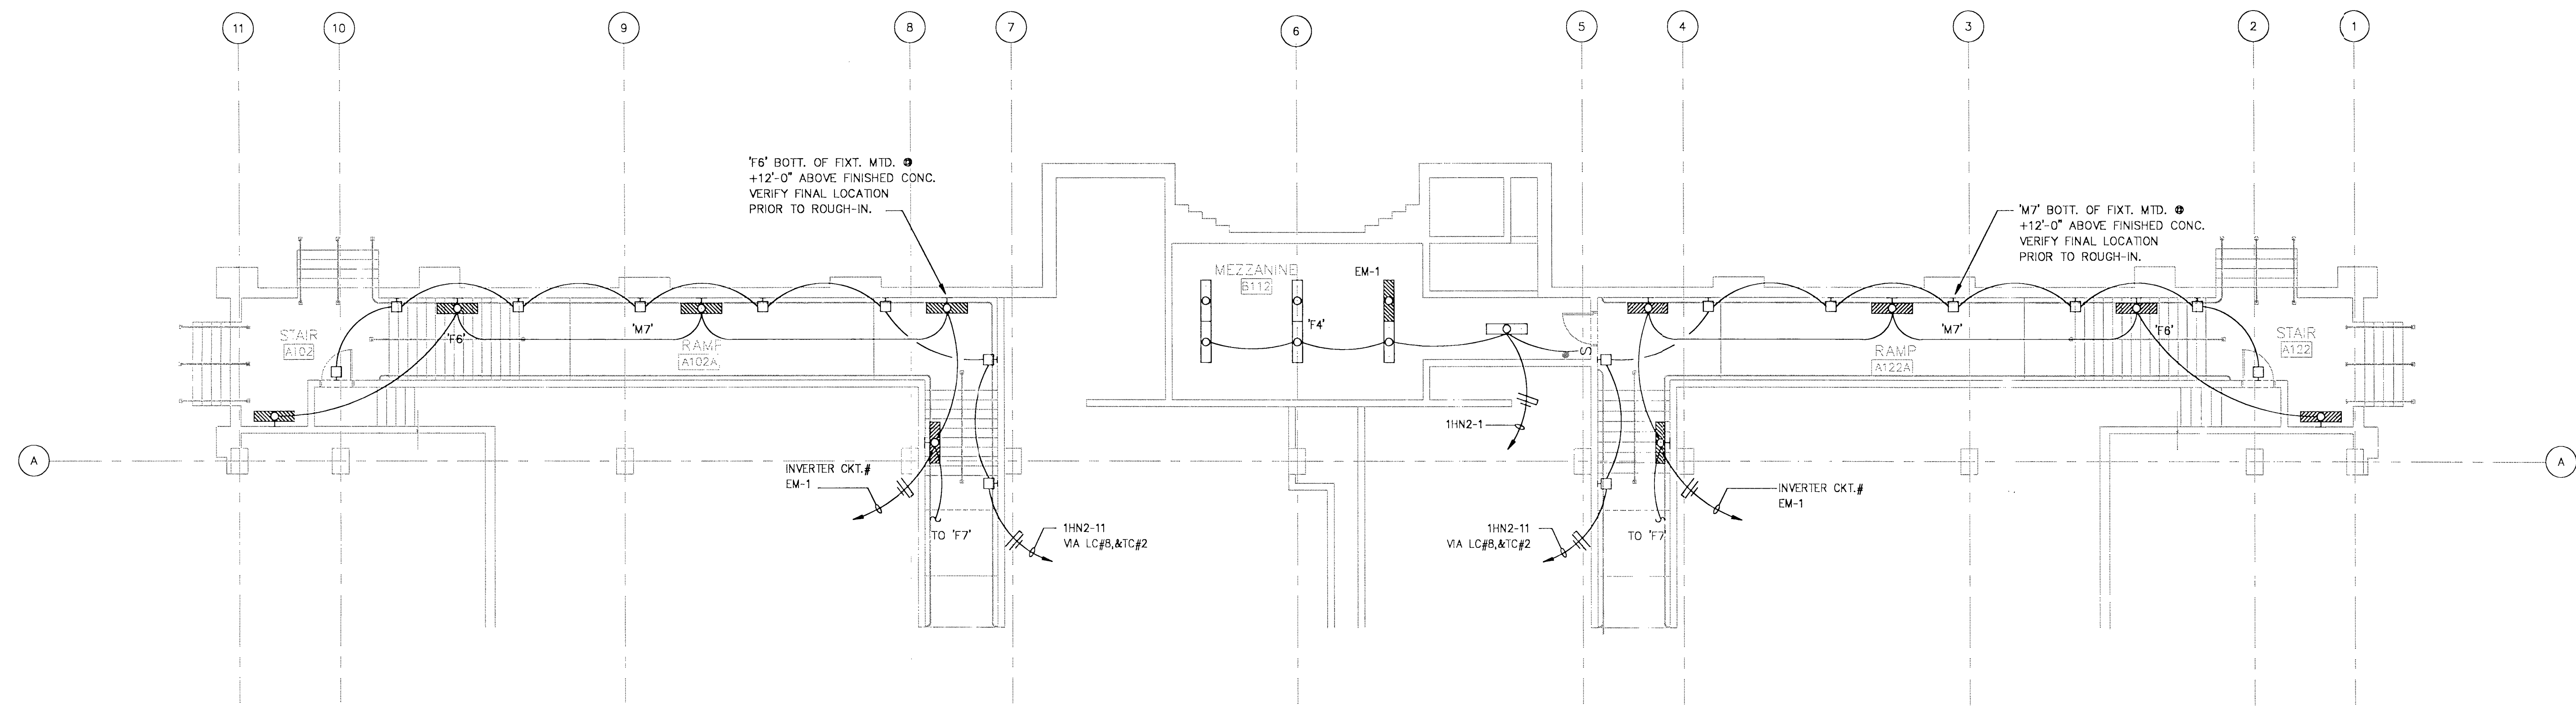

FOOTBALL STADIUM INTERIOR RAMP LIGHTING PLAN
SCALE : 1/8" = 1'-0"

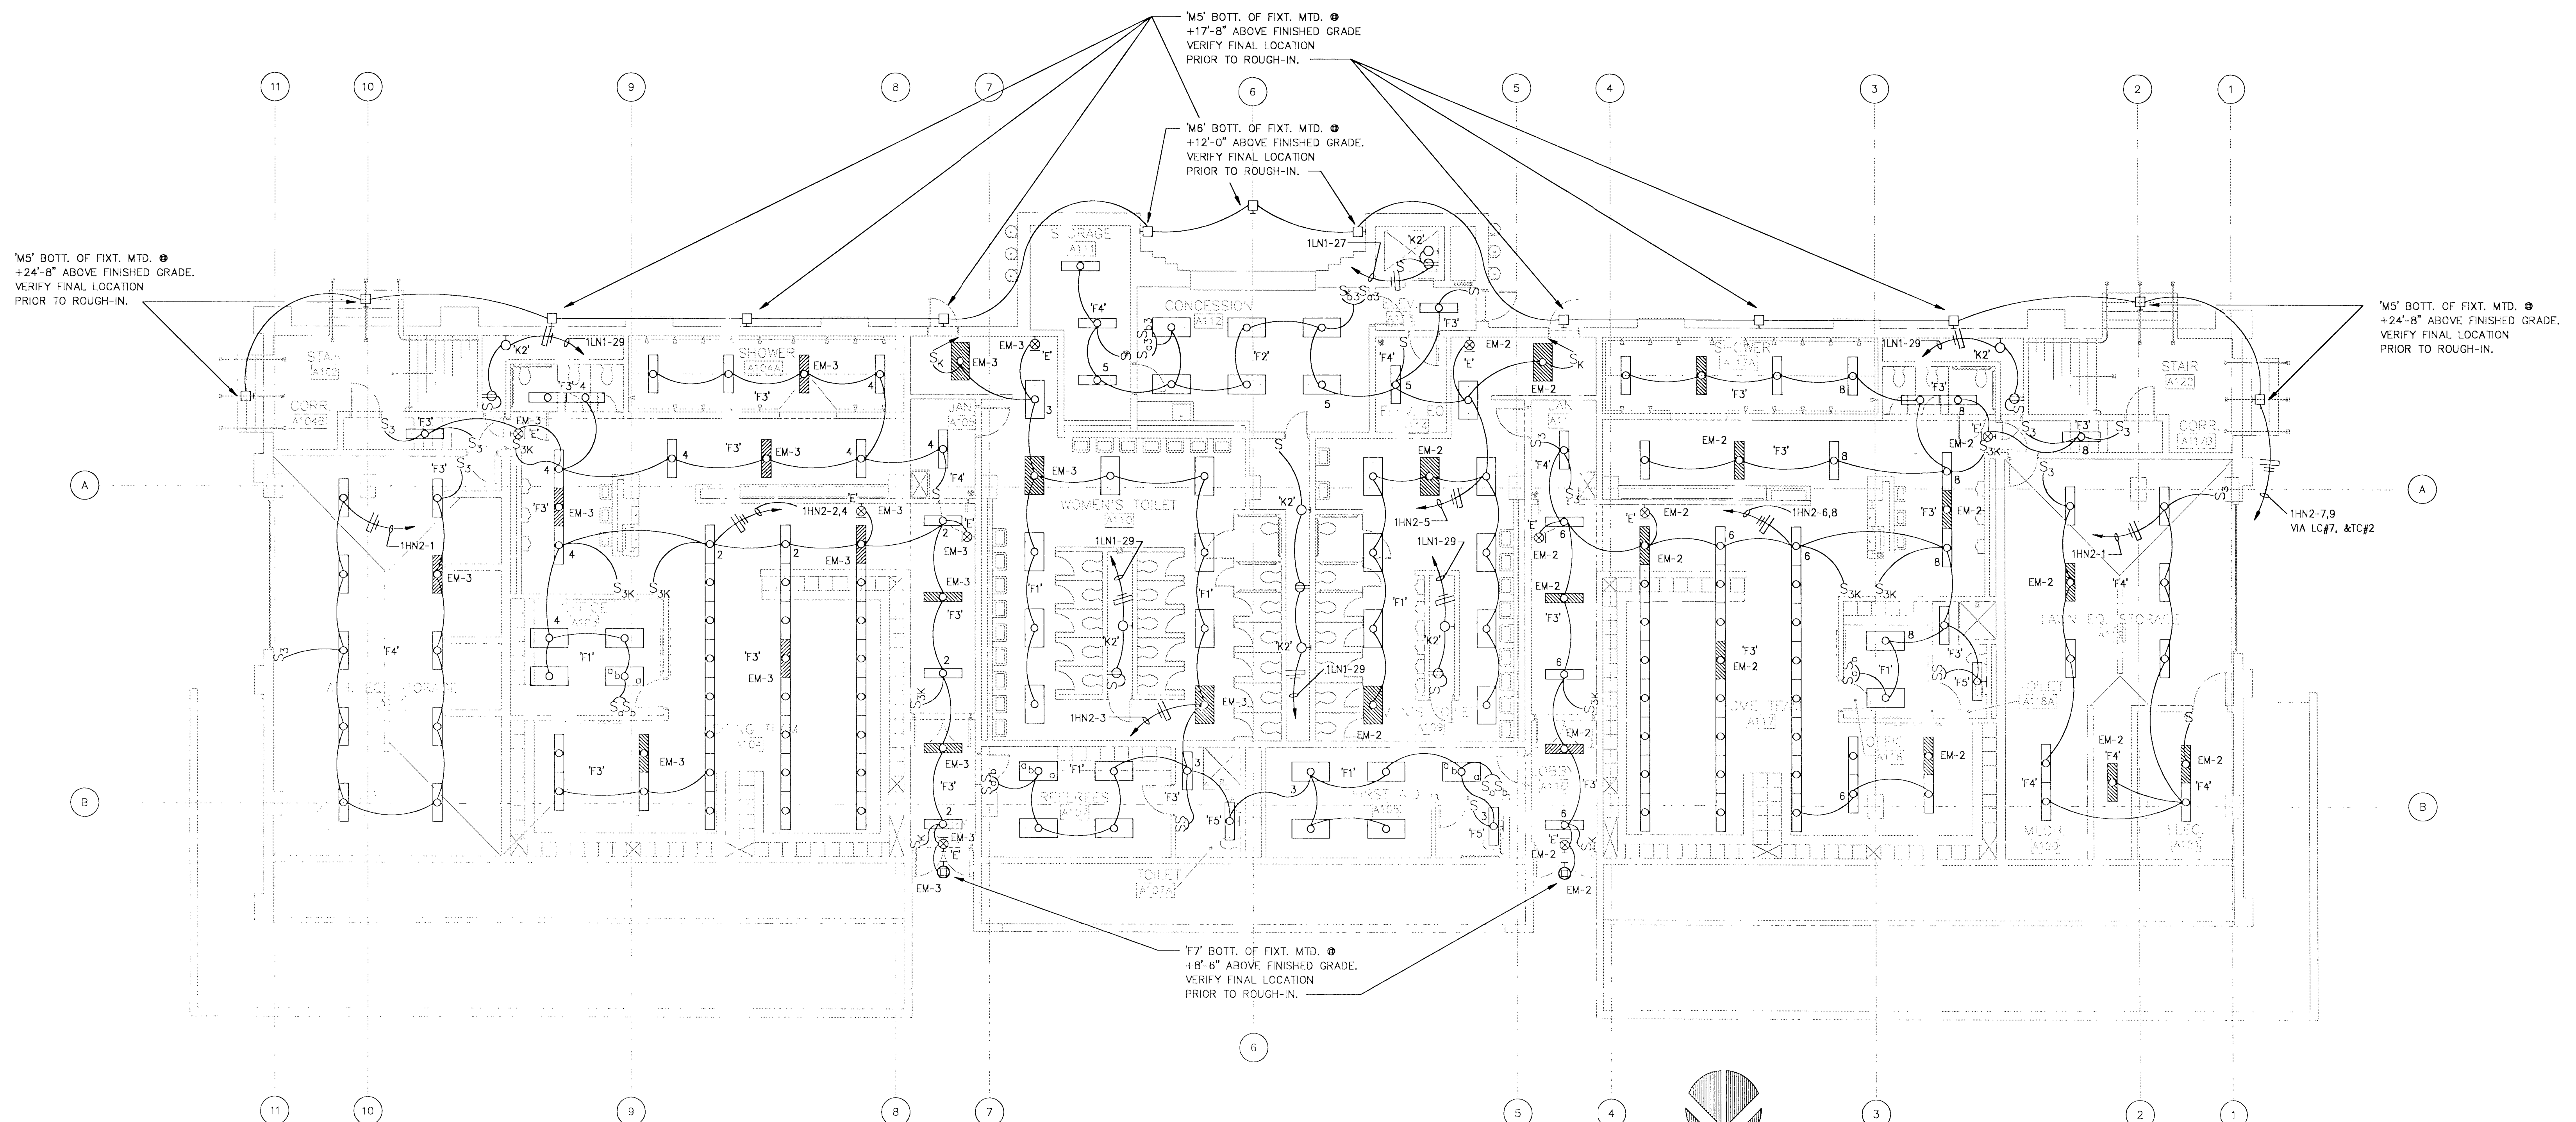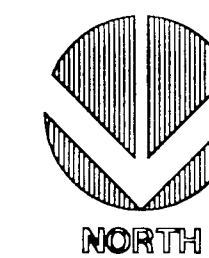

FOOTBALL STADIUM LIGHTING FLOOR PLAN
SCALE : 1/8" = 1'-0"

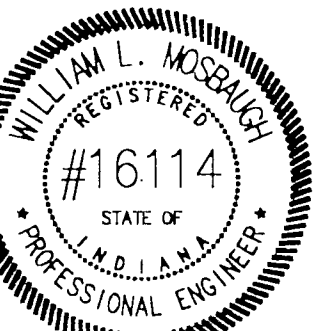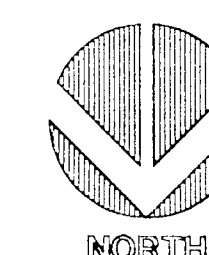

CERTIFIED

THE ODLE MCQUIRE & SHOOK CORPORATION
ARCHITECTURE • ENGINEERING • LANDSCAPE ARCHITECTURE • INTERIOR DESIGN
5765 NORTH STATE ROAD 37, POST OFFICE BOX 54428, INDIANAPOLIS, INDIANA 46250, 317/842-0000

REVISIONS


© Copyright 1994 by THE ODLE MCQUIRE & SHOOK CORPORATION. Copyright includes architectural work, building design, plans or drawings, and specifications. Architectural work is the owned form and use of the arrangement and composition of space and elements in the design. Reproduction without written permission is prohibited.

MICHIGAN CITY SPORTS COMPLEX
AMES FIELD
MICHIGAN CITY, INDIANA



PROJECT NO. 93052
DATE MAY 31, 1994
drawn by: JUC
checked by: RSB

E201
FOOTBALL STADIUM
LIGHTING PLAN


P:\ELEDWMS\93052\01 05-27-94 12:34:16

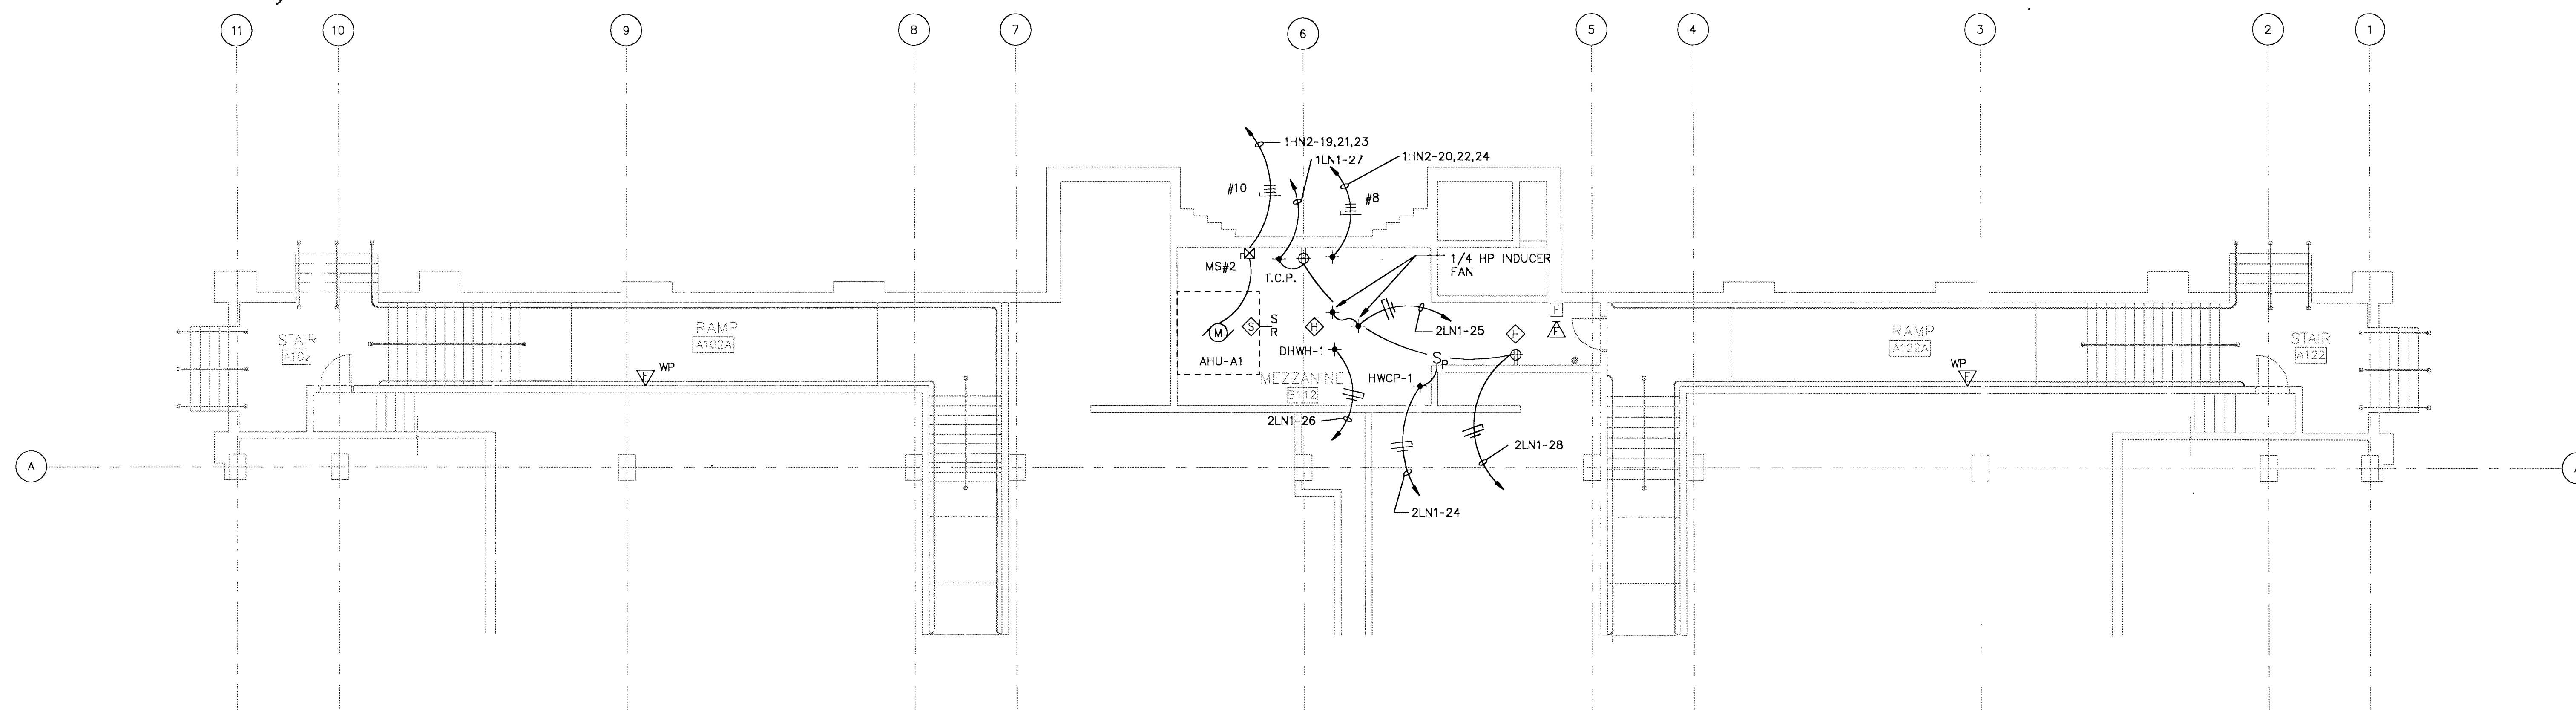

FOOTBALL STADIUM INTERIOR RAMP POWER & SIGNAL PLAN
SCALE : 1/8" = 1'-0"

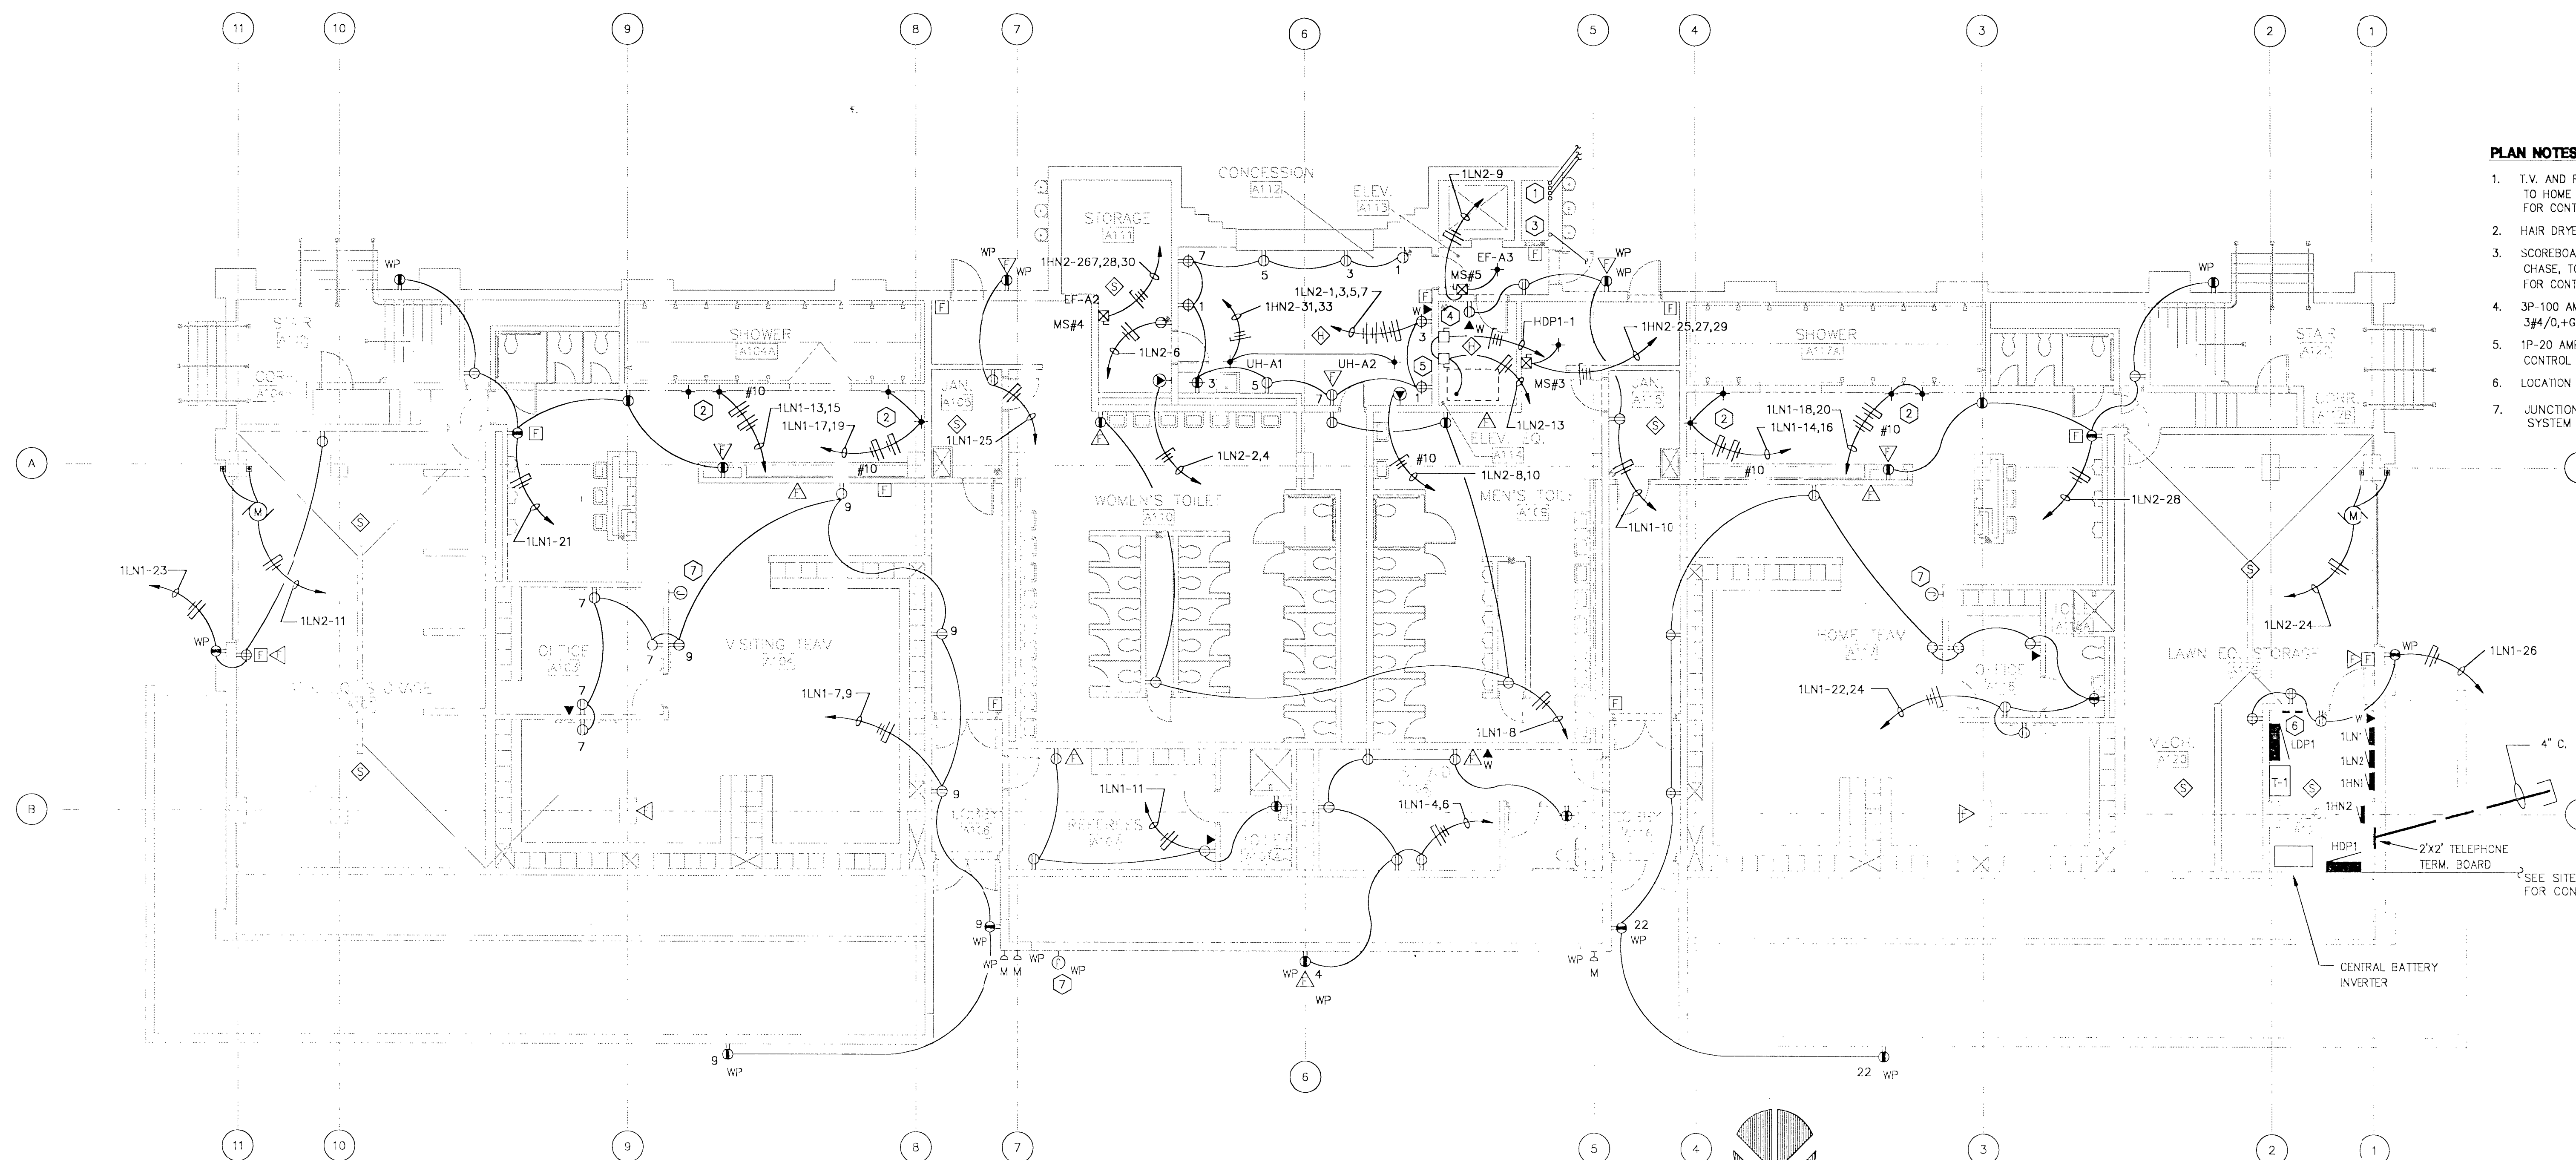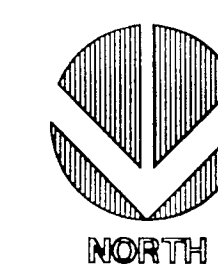

FOOTBALL STADIUM POWER & SIGNAL FLOOR PLAN
SCALE : 1/8" = 1'-0"

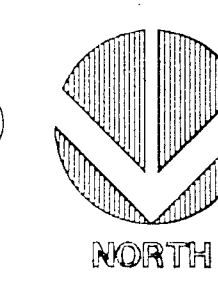

PLAN NOTES:

1. T.V. AND RADIO CONDUITS, UP THRU CHASE, TO HOME AND VISITOR'S BROADCAST BOOTHS. FOR CONTINUATION, SEE E204.
2. HAIR DRYERS
3. SCOREBOARD CONTROLLER CONDUITS, UP THRU CHASE, TO BROADCAST BOOTH AND PRESS BOX. FOR CONTINUATION, SEE E204.
4. 3P-100 AMP DISCONNECT SWITCH, FOR ELEVATOR 3#4/0,+G,+2'C. (FUSED).
5. 1P-20 AMP DISCONNECT SWITCH, FOR ELEVATOR CONTROL PANEL.
6. LOCATION OF TIME CLOCKS TO# 1, & TO# 1.
7. JUNCTION BOXES WITH COVER TO SOUND SYSTEM RACK.



CERTIFIED

THE ODLE MCGUIRE & SHOOK CORPORATION
ARCHITECTURE • ENGINEERING • LANDSCAPE ARCHITECTURE • INTERIOR DESIGN
6795 NORTH STATE ROAD 37, POST OFFICE BOX 2148, BLOOMINGTON, INDIANA 47402, 812/876-2020
8275 ALLISON POINTE TRAIL, POST OFFICE BOX 50428, INDIANAPOLIS, INDIANA 46250, 317/642-0000


REVISIONS

© Copyright 1984 by THE ODLE MCGUIRE & SHOOK CORPORATION. Copyright includes architectural work, building design, plans or drawings, and specifications. Architectural work in the design form as well as the arrangement and composition of space and elements in the design. Reproduction without written permission is prohibited.

MICHIGAN CITY SPORTS COMPLEX
AMES FIELD
MICHIGAN CITY, INDIANA


PROJECT NO. 93052
DATE MAY 31, 1984
drawn by: JJC/ KWB
checked by: RSB

E202
FOOTBALL STADIUM
POWER & SIGNAL PLAN

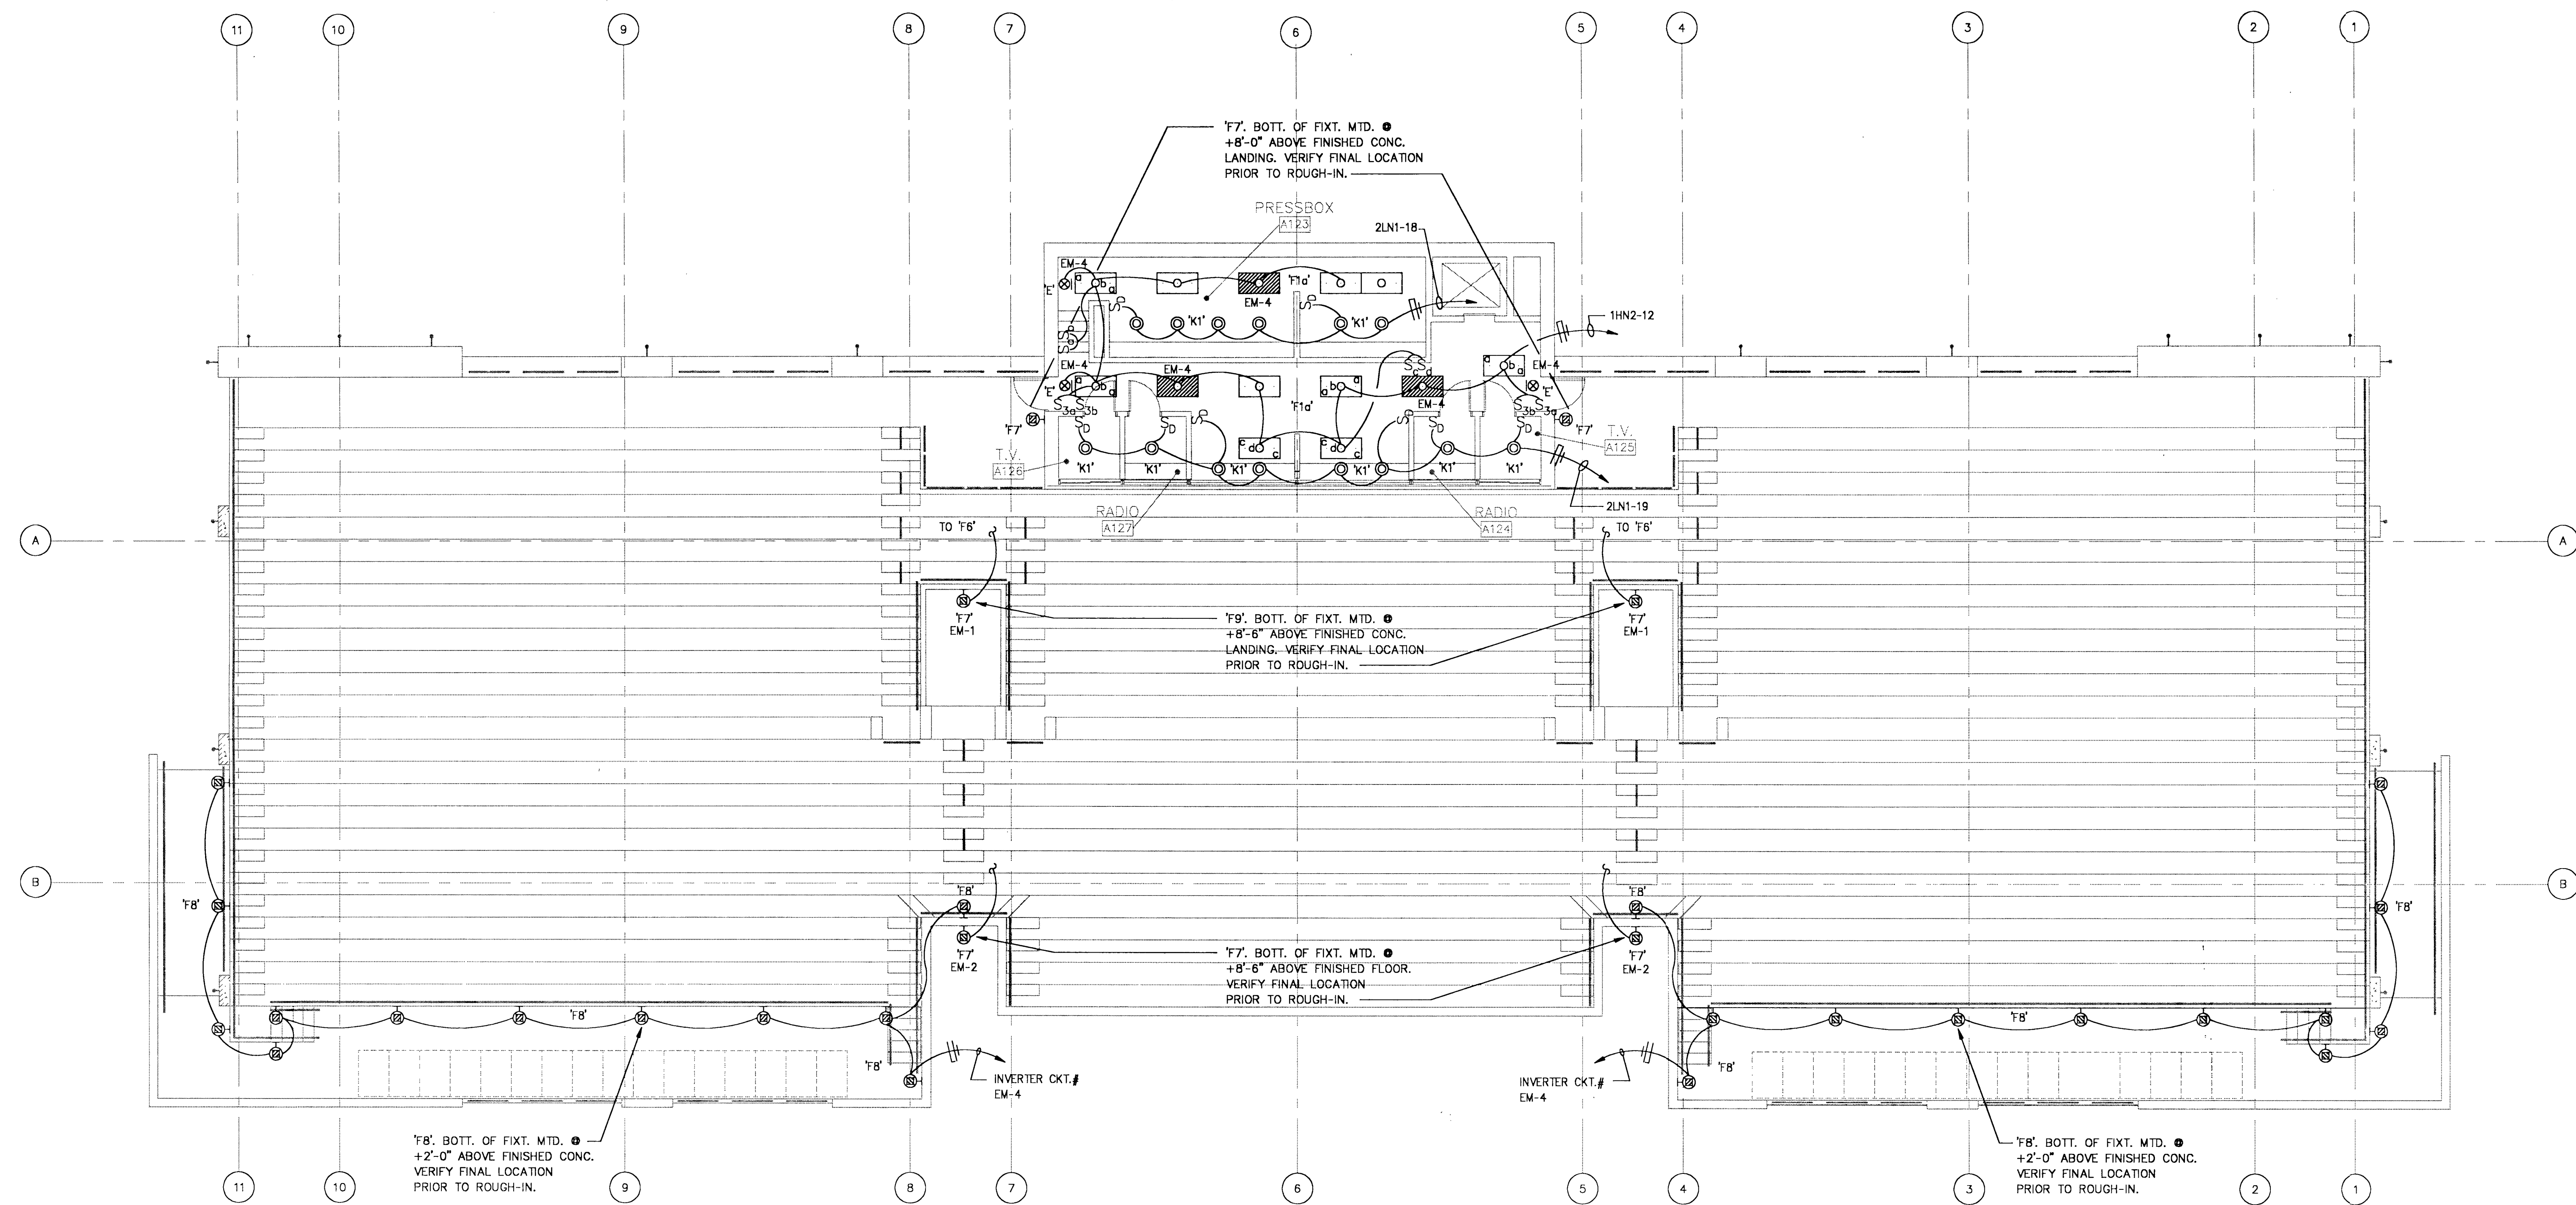

FOOTBALL STADIUM SEATING LIGHTING PLAN


SCALE : 1/8" = 1'-0"

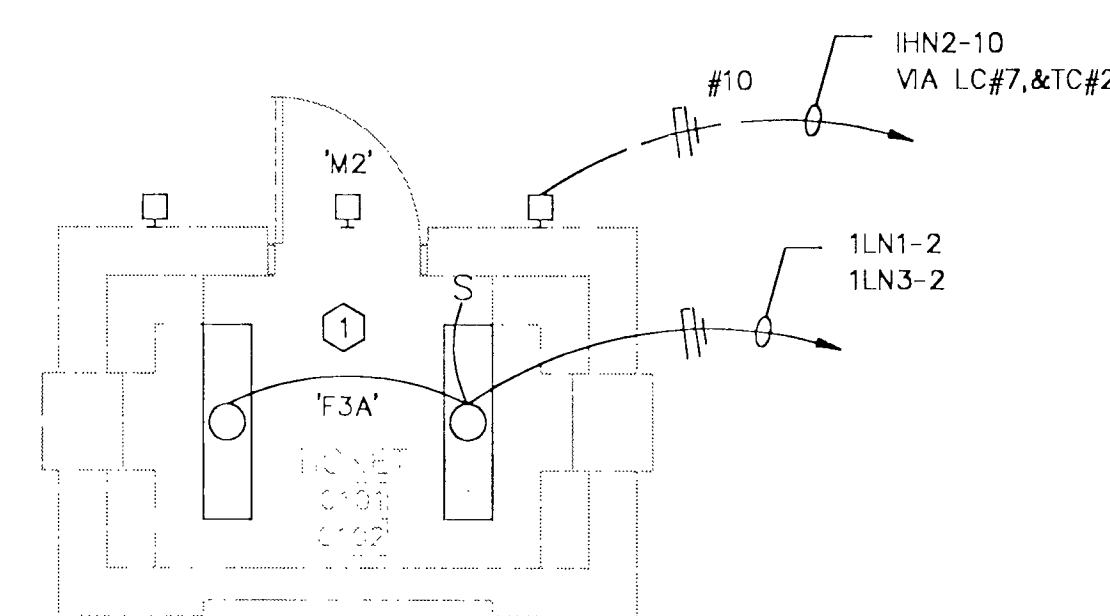

TICKET BOOTH LIGHTING PLAN
(TYPICAL OF 2)
SCALE : 1/4" = 1'-0"

PLAN NOTES :

1. TYPE 'F3A' SAME AS TYPE 'F3', EXCEPT 120V.
2. ALL EMERGENCY UNITS IN VISITOR'S TOILET AND CONCESSION, SHALL BE BATTERY INVERTER IN THE BALLAST CHANNEL, (TYPICAL OF 5).

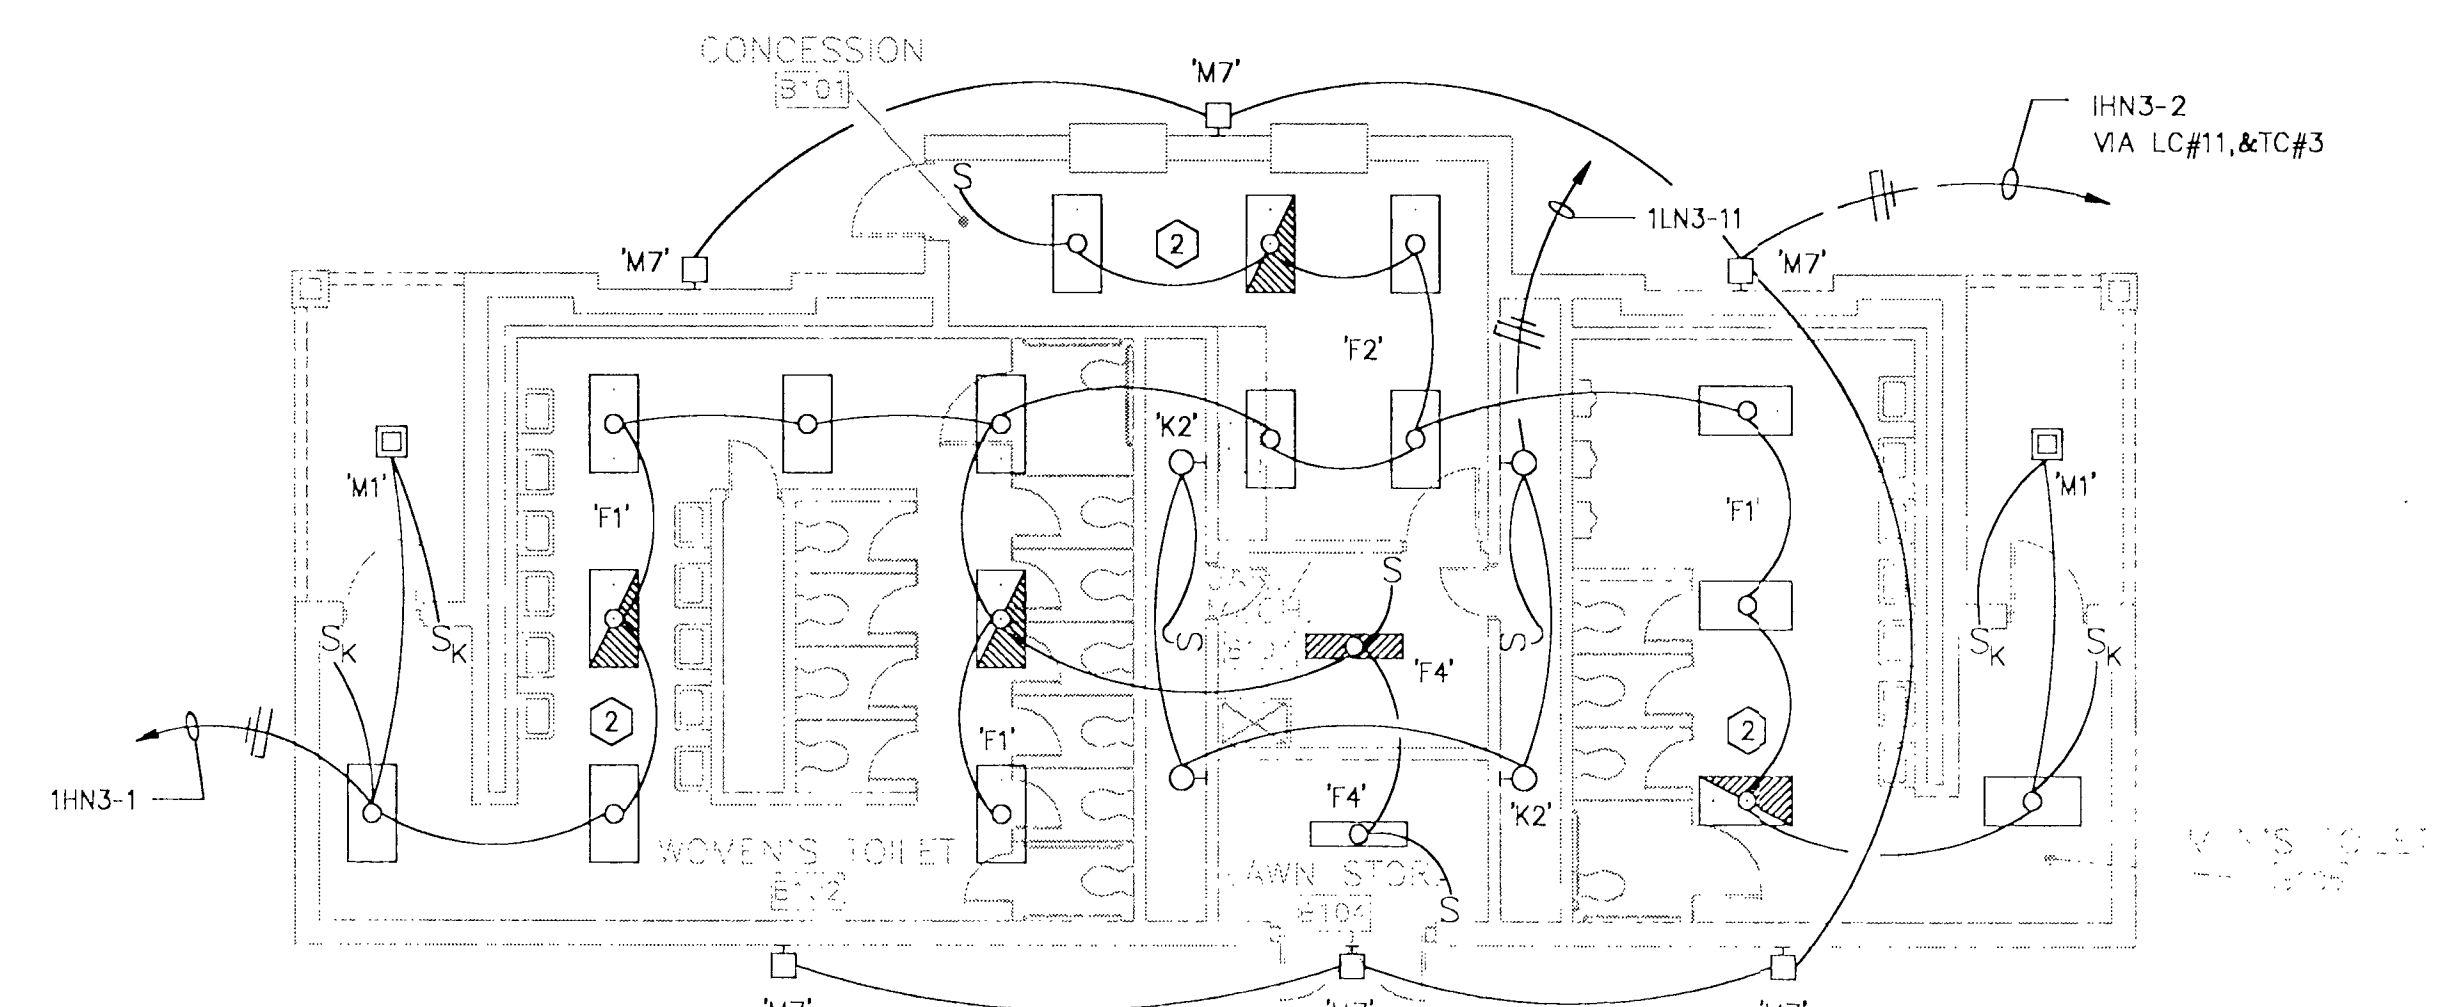

VISITOR TOILET & CONCESSION LIGHTING PLAN
SCALE : 1/8" = 1'-0"



CERTIFIED

THE ODLE MCQUIRE & SHOOK CORPORATION
ARCHITECTURE • ENGINEERING • LANDSCAPE ARCHITECTURE • INTERIOR DESIGN
8275 ALISON POINTE TRAIL, POST OFFICE BOX 54428, INDIANAPOLIS, INDIANA 46250, 317/842-0000

REVISIONS


© Copyright 1994 by THE ODLE MCQUIRE & SHOOK CORPORATION. Copyright includes architectural work, building design, plans or drawings, and specifications. Architectural work is the owner's property and shall remain in the design. Reproduction without written permission is prohibited.

MICHIGAN CITY SPORTS COMPLEX
AMES FIELD
MICHIGAN CITY, INDIANA


PROJECT NO. 93052
DATE MAY 31, 1994
drawn by JUC/ KW3
checked by: FSB

E203

FOOTBALL STADIUM,
CONCESSIONS, &
TICKET BOOTHS
LIGHTING PLAN

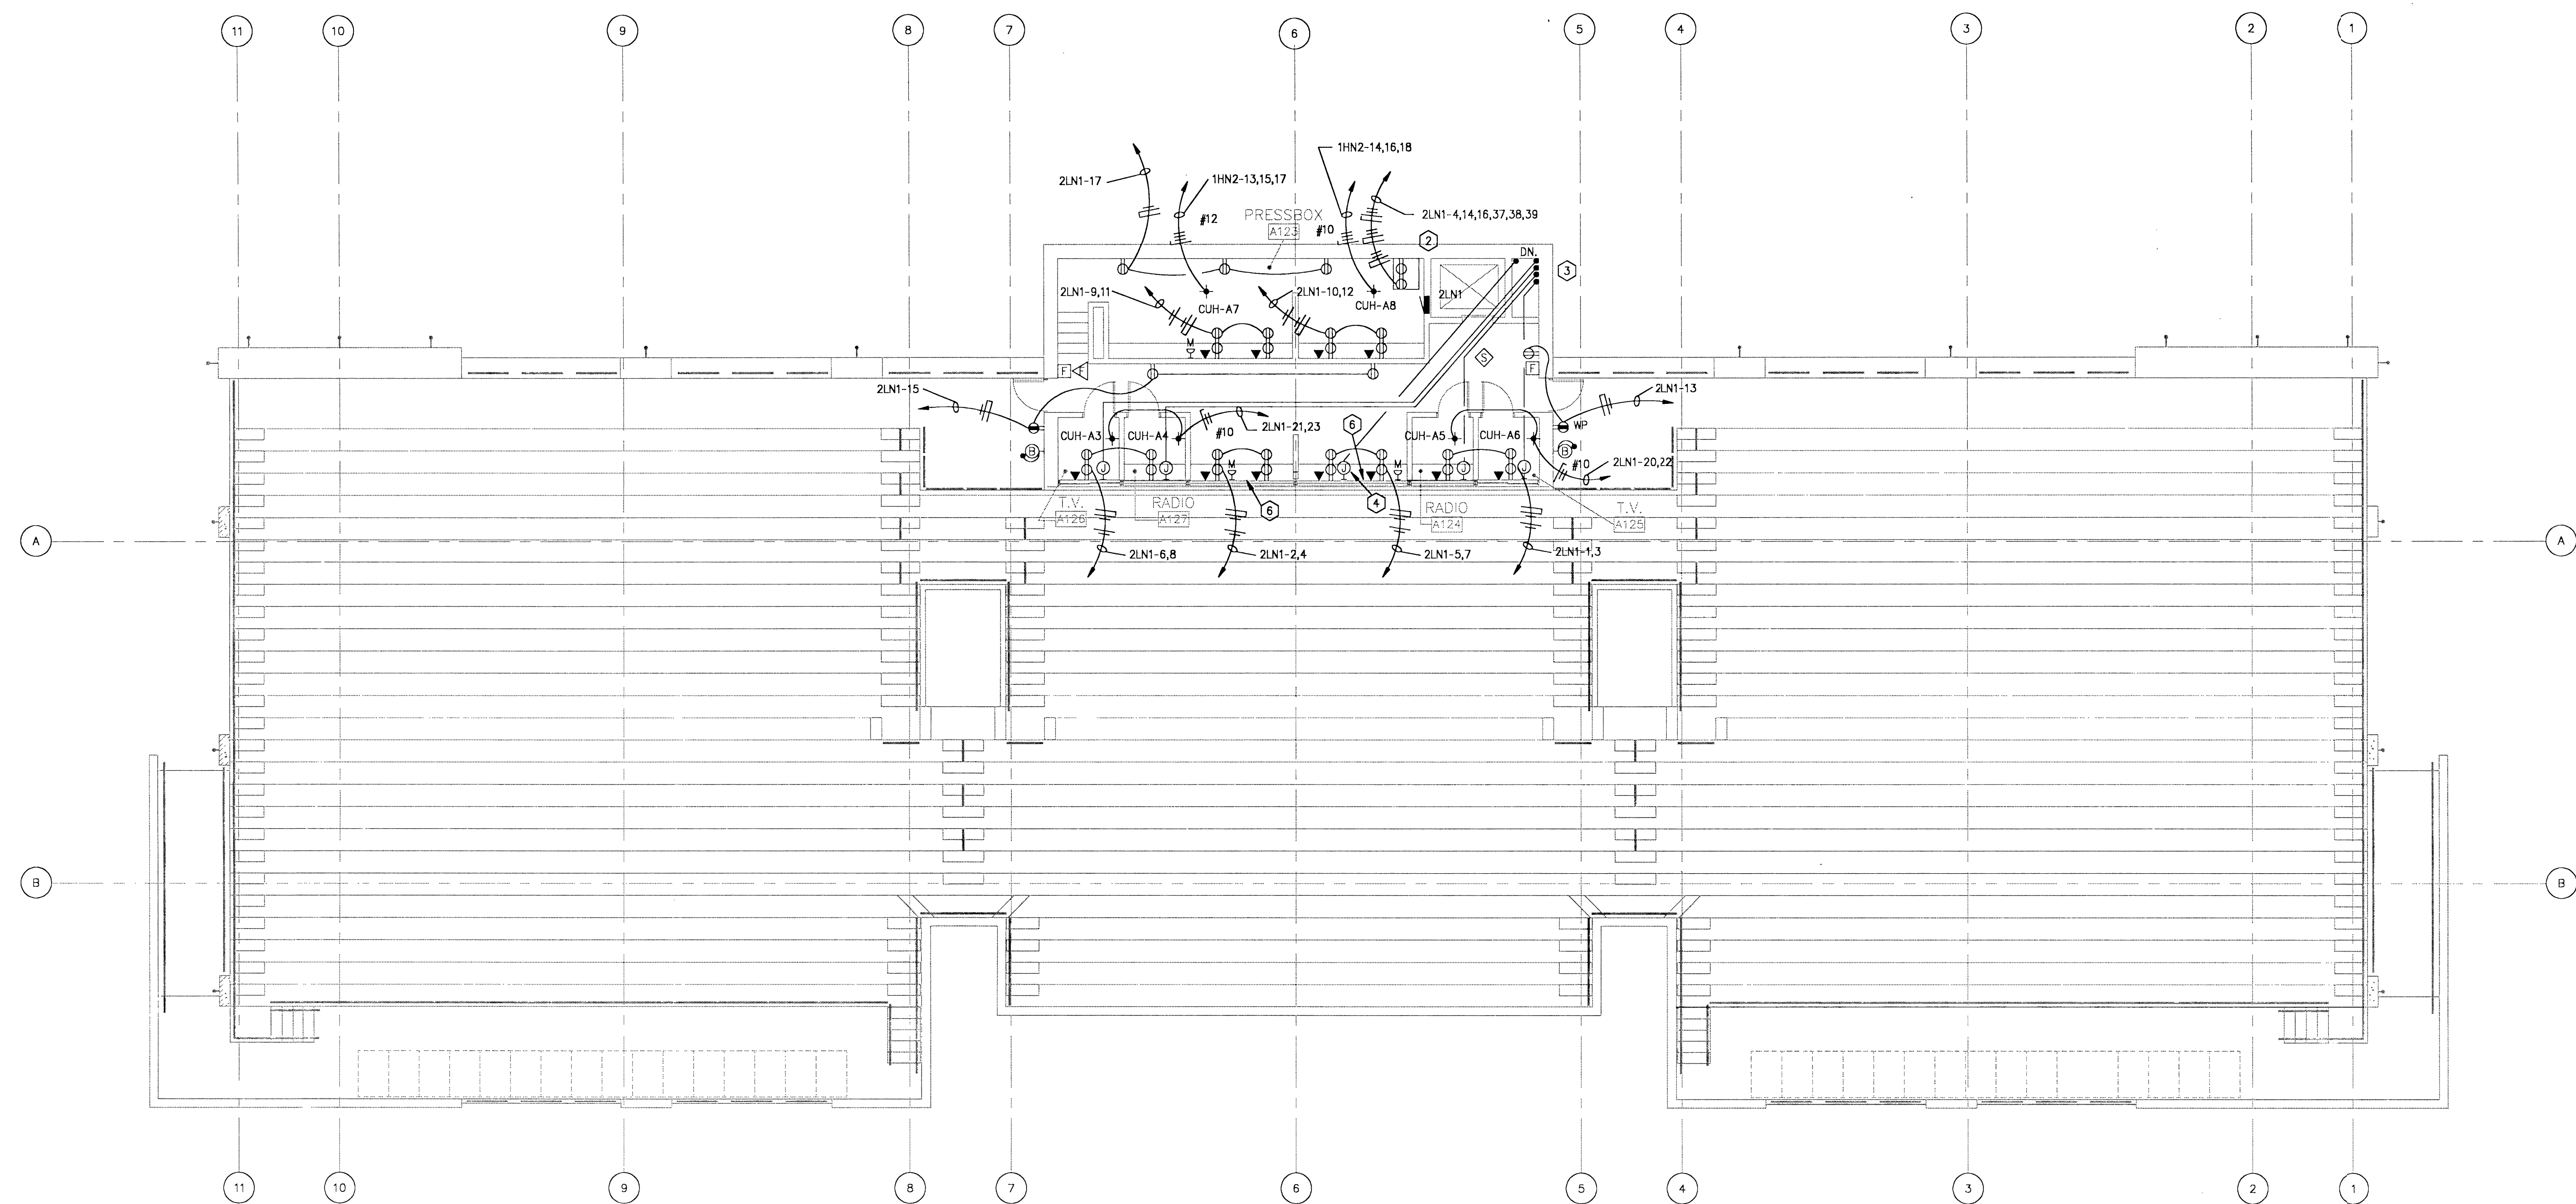


FOOTBALL STADIUM SEATING POWER & SIGNAL PLAN
SCALE : 1/8" = 1'-0"

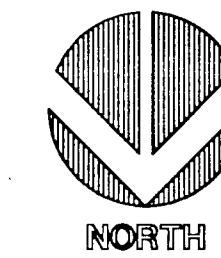


PLAN NOTES:


1. PANELBOARD 11N3 WITH TRANSFORMER T-2
WALL MOUNTED ABOVE.
2. SOUND SYSTEM RACK.
3. SEE RISER DIAGRAM, E302, FOR RADIO & TELEVISION
CONDUIT DISTRIBUTION.
4. SCOREBOARD CONTROLLER, WITH 4 JUNCTION BOXES
WITH 4-3/4" CONDUITS. SEE DETAIL ON DRAWING E301.
5. 120 VOLT SMOKE DETECTORS, WITH LIGHT/ SIREN.
6. PRESS BOX MONITOR SPEAKERS MOUNTED ABOVE
WINDOW.

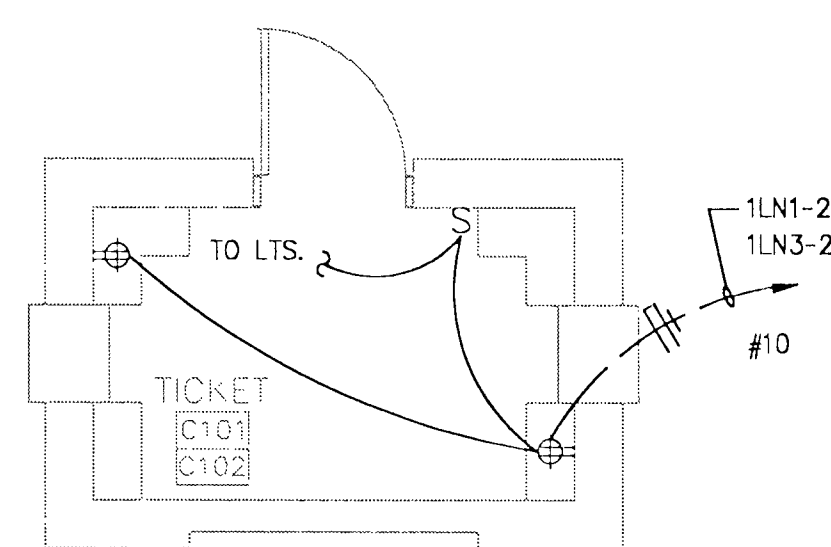


TICKET BOOTH POWER & SIGNAL PLAN
(TYPICAL OF 2)
SCALE : 1/4" = 1'-0"

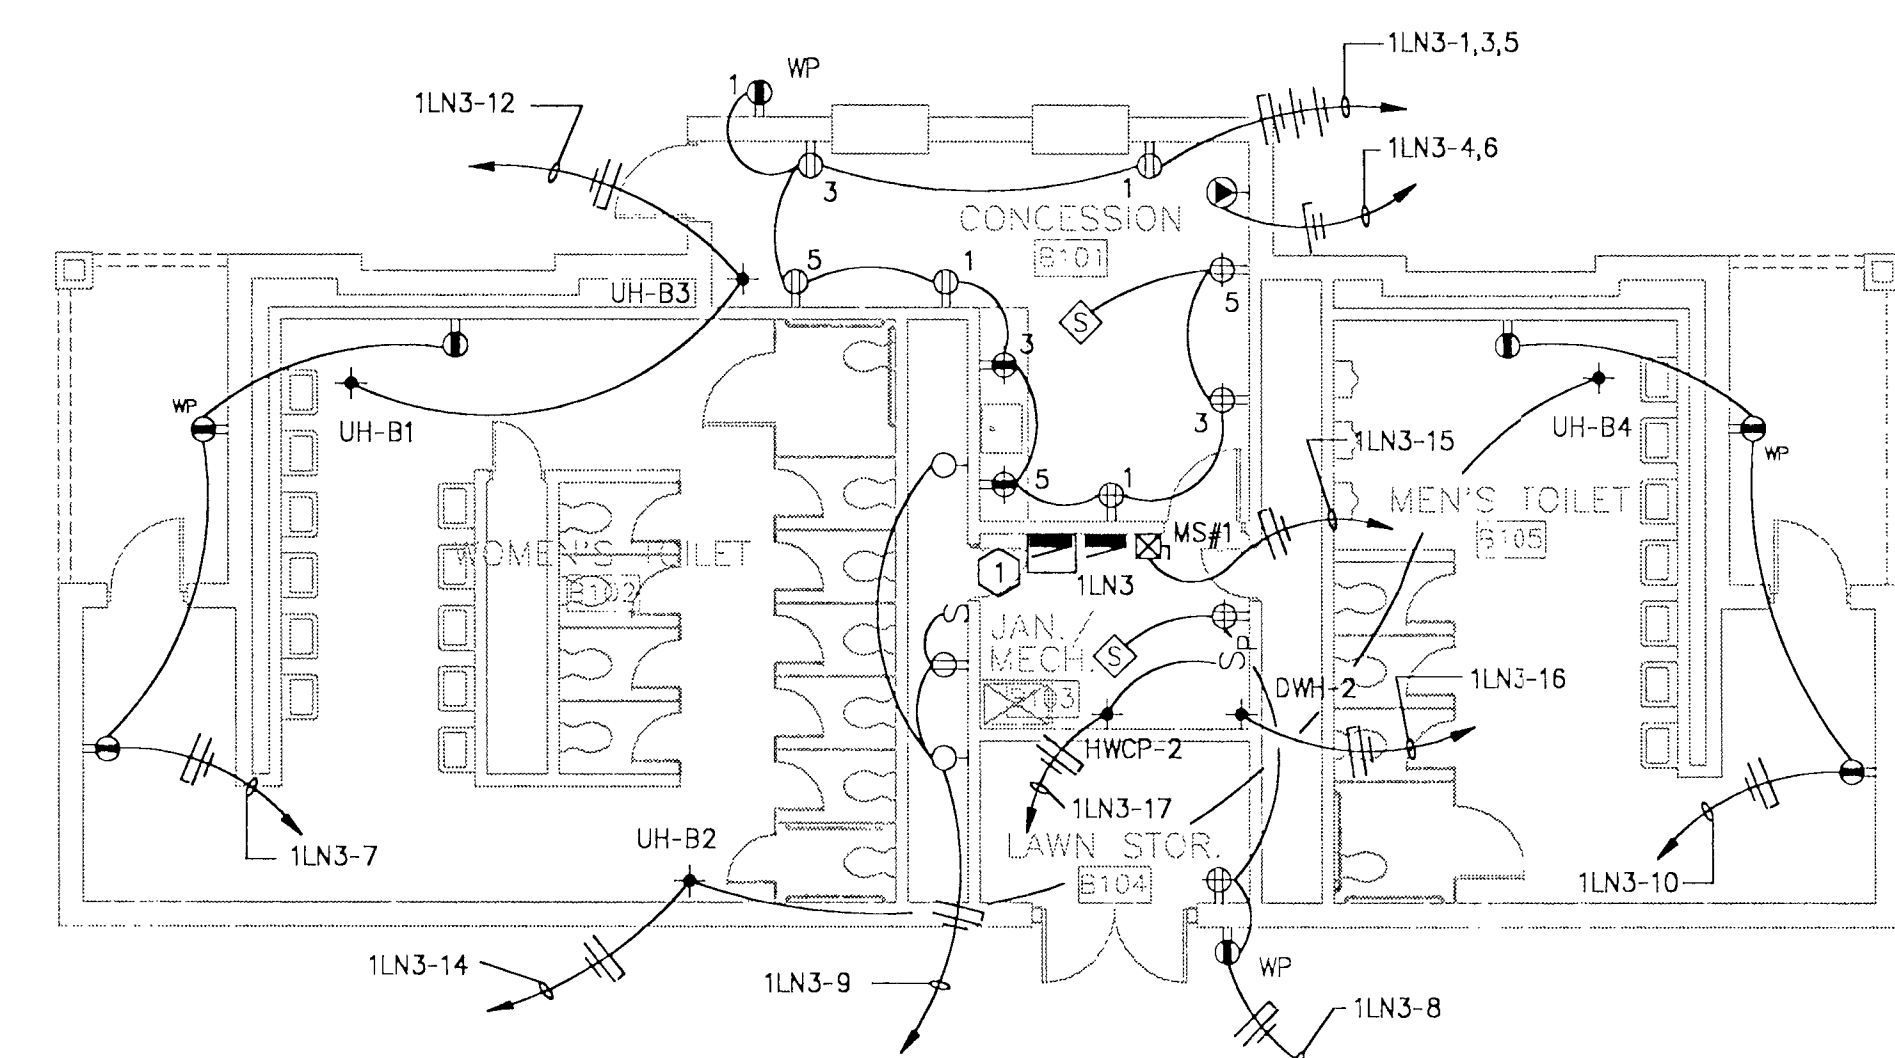


VISITOR TOILET & CONSESSION POWER & SIGNAL PLAN
SCALE : 1/8" = 1'-0"

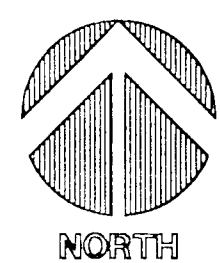


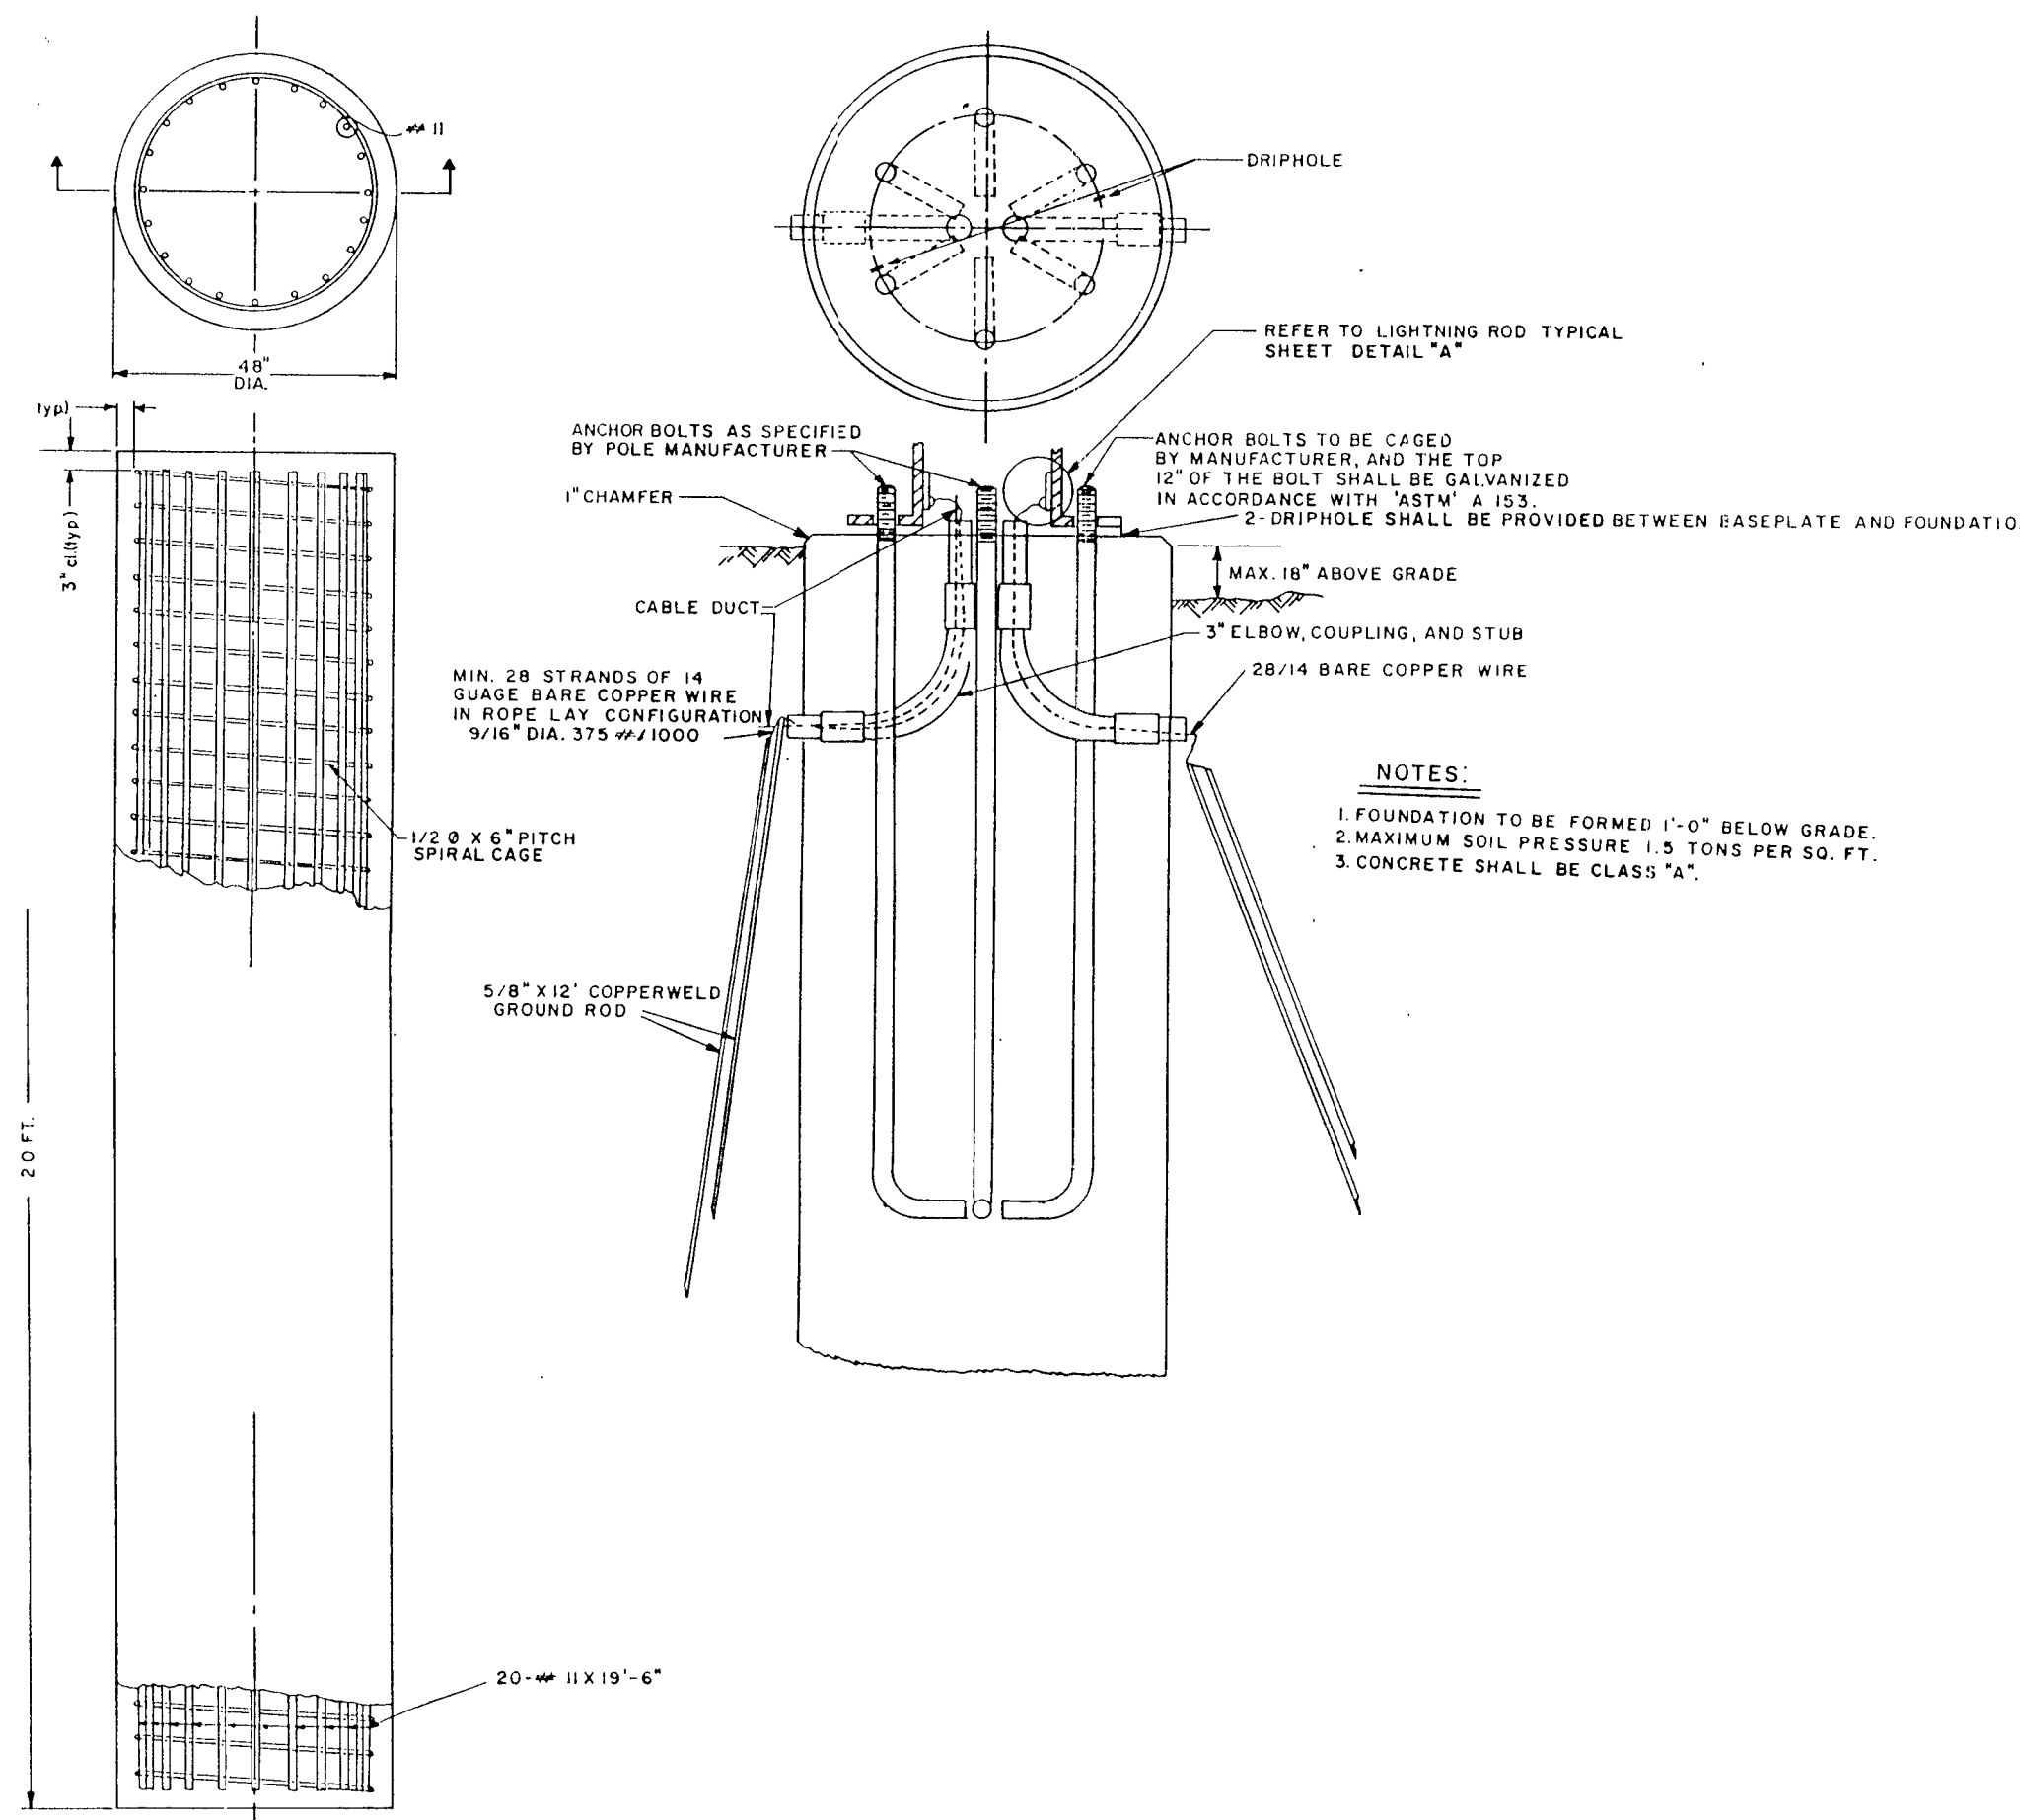


TOWER FOUNDATION DETAIL
N.T.S.

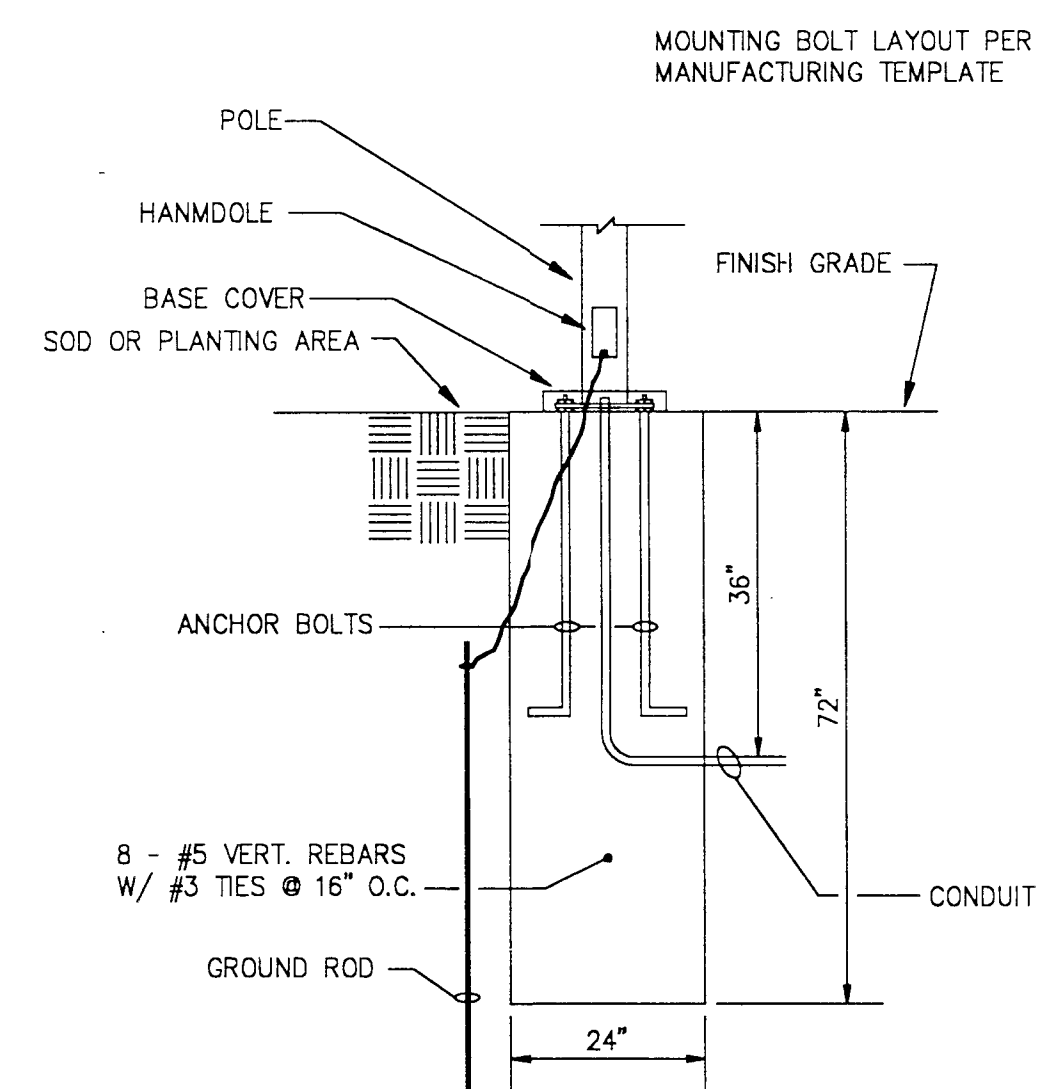


LIGHT POLE BASE DETAIL
N.T.S.

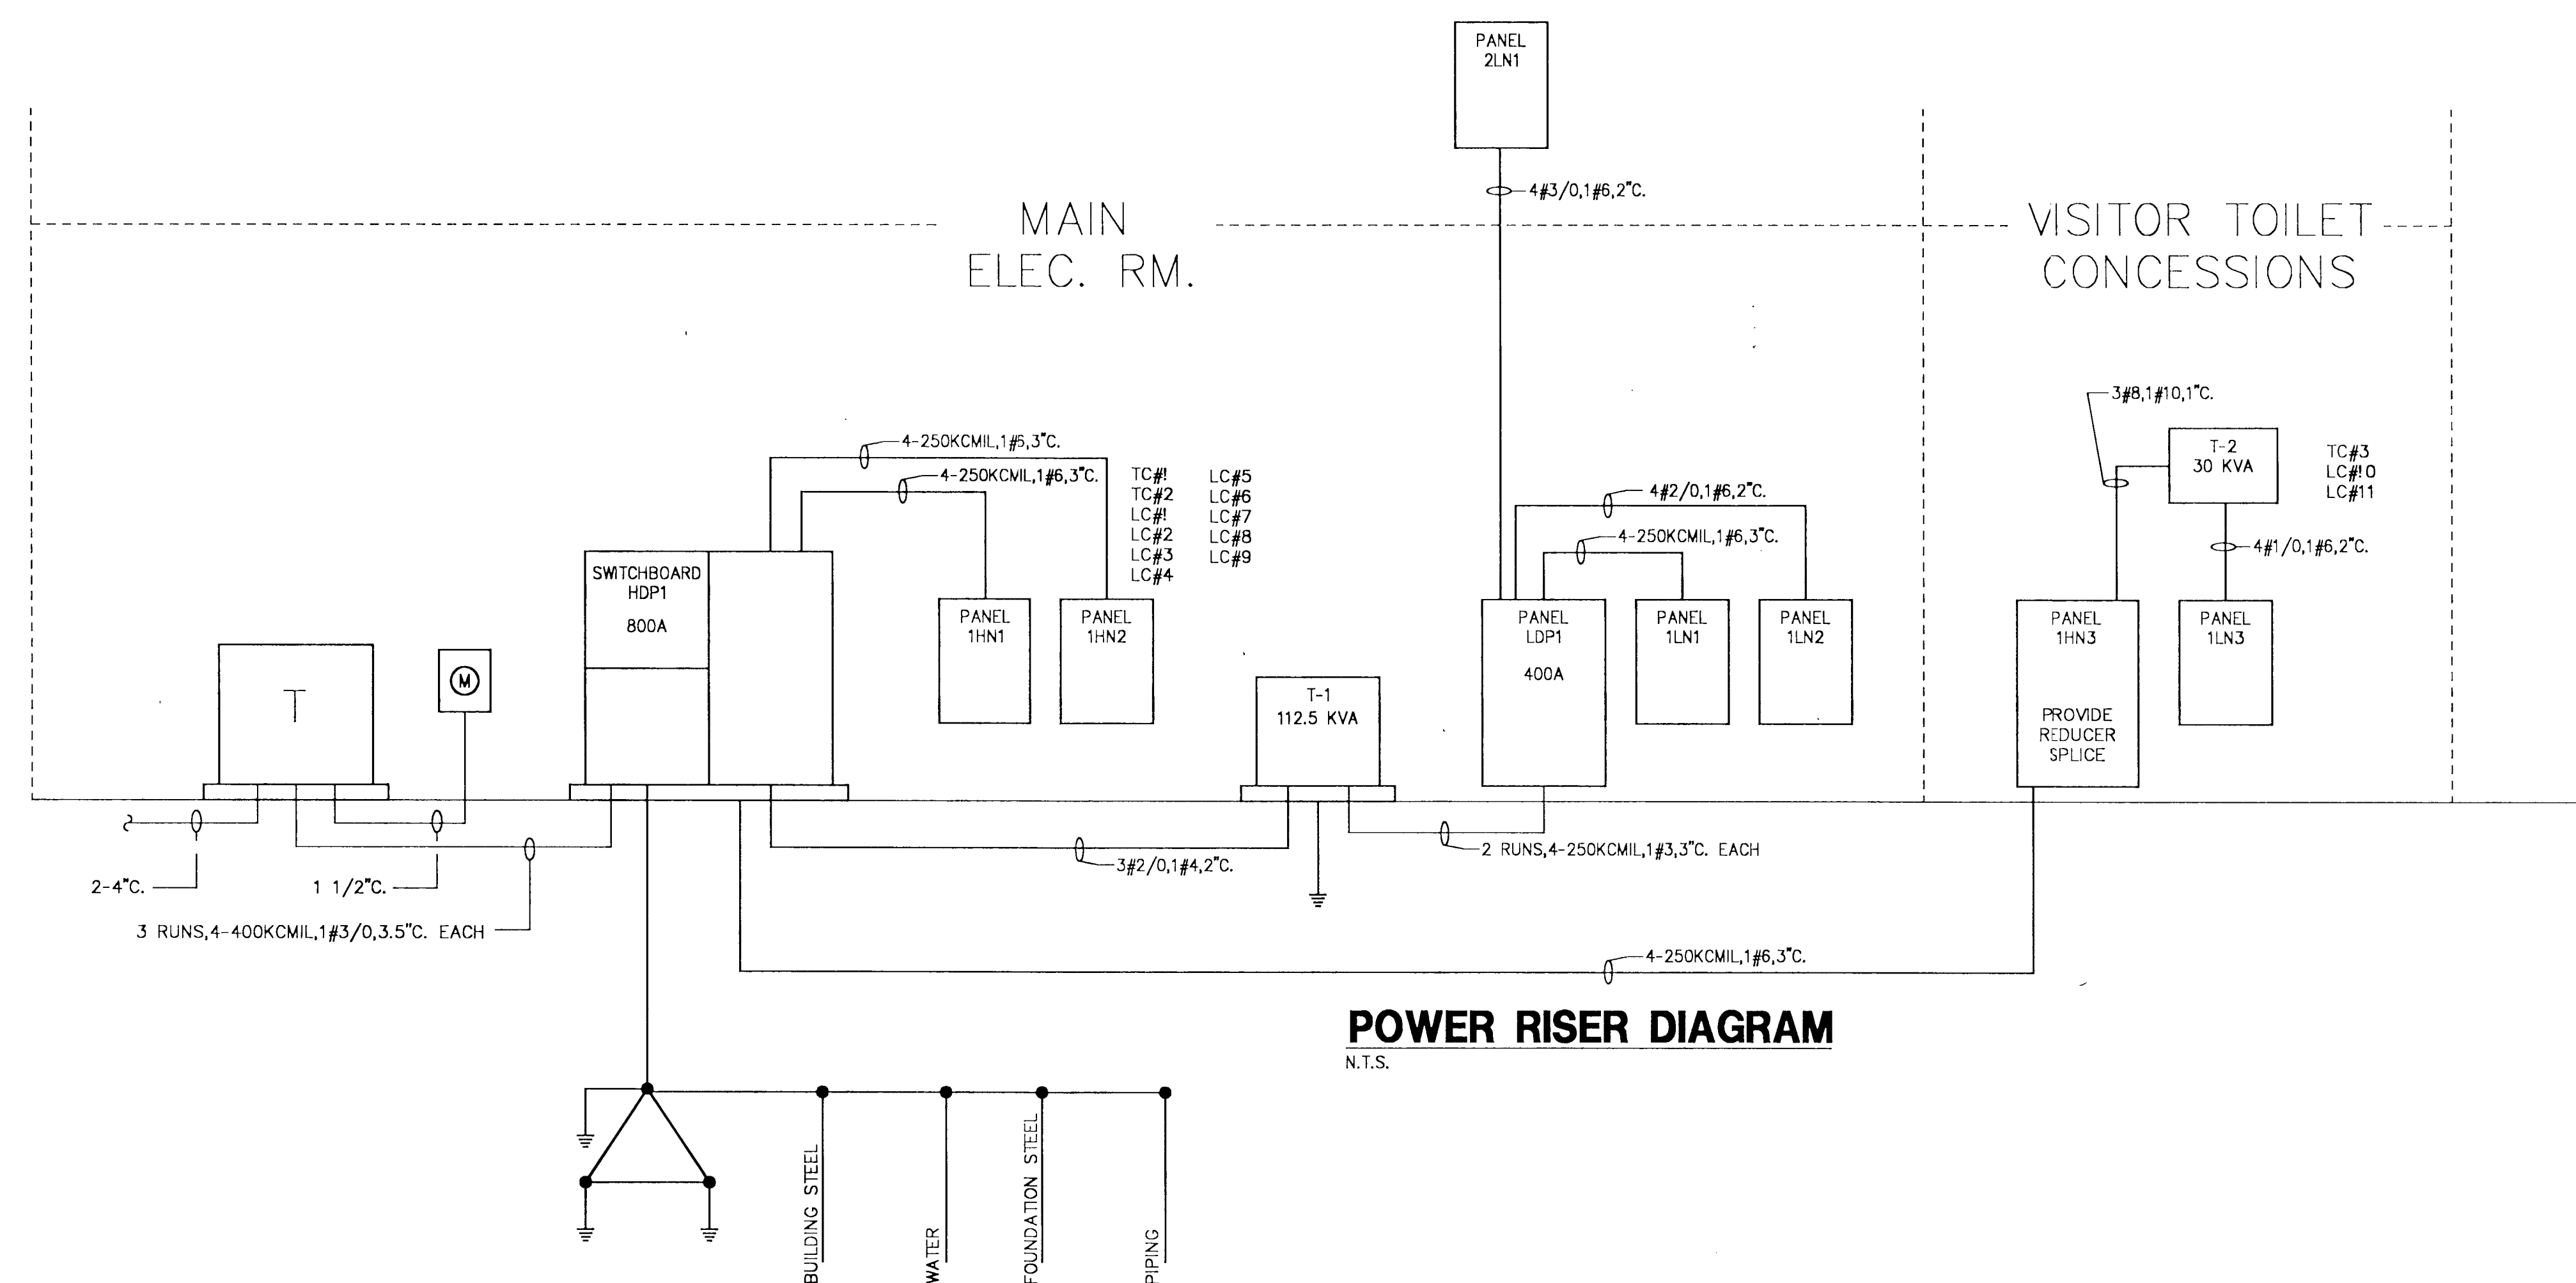



POWER RISER DIAGRAM
N.T.S.

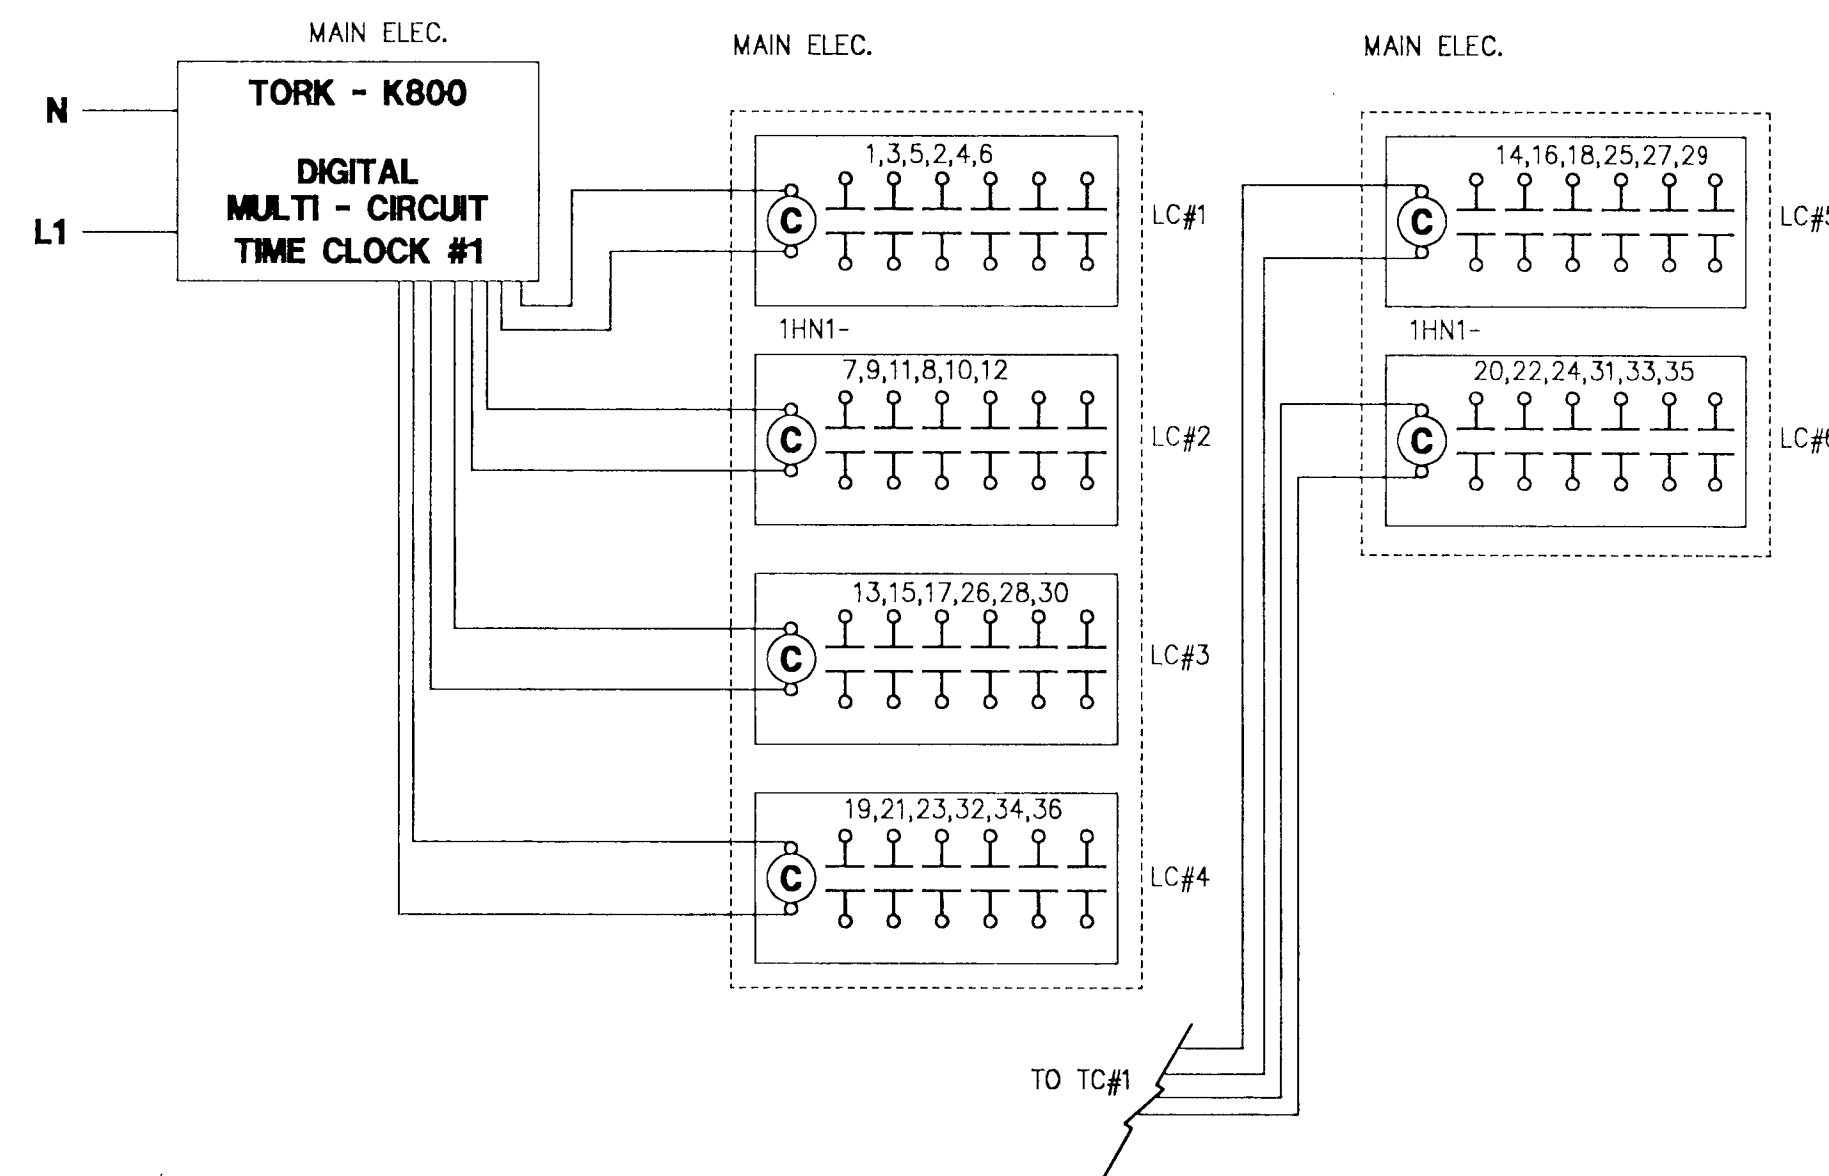

LIGHTING CONTROL DIAGRAM
NOT TO SCALE

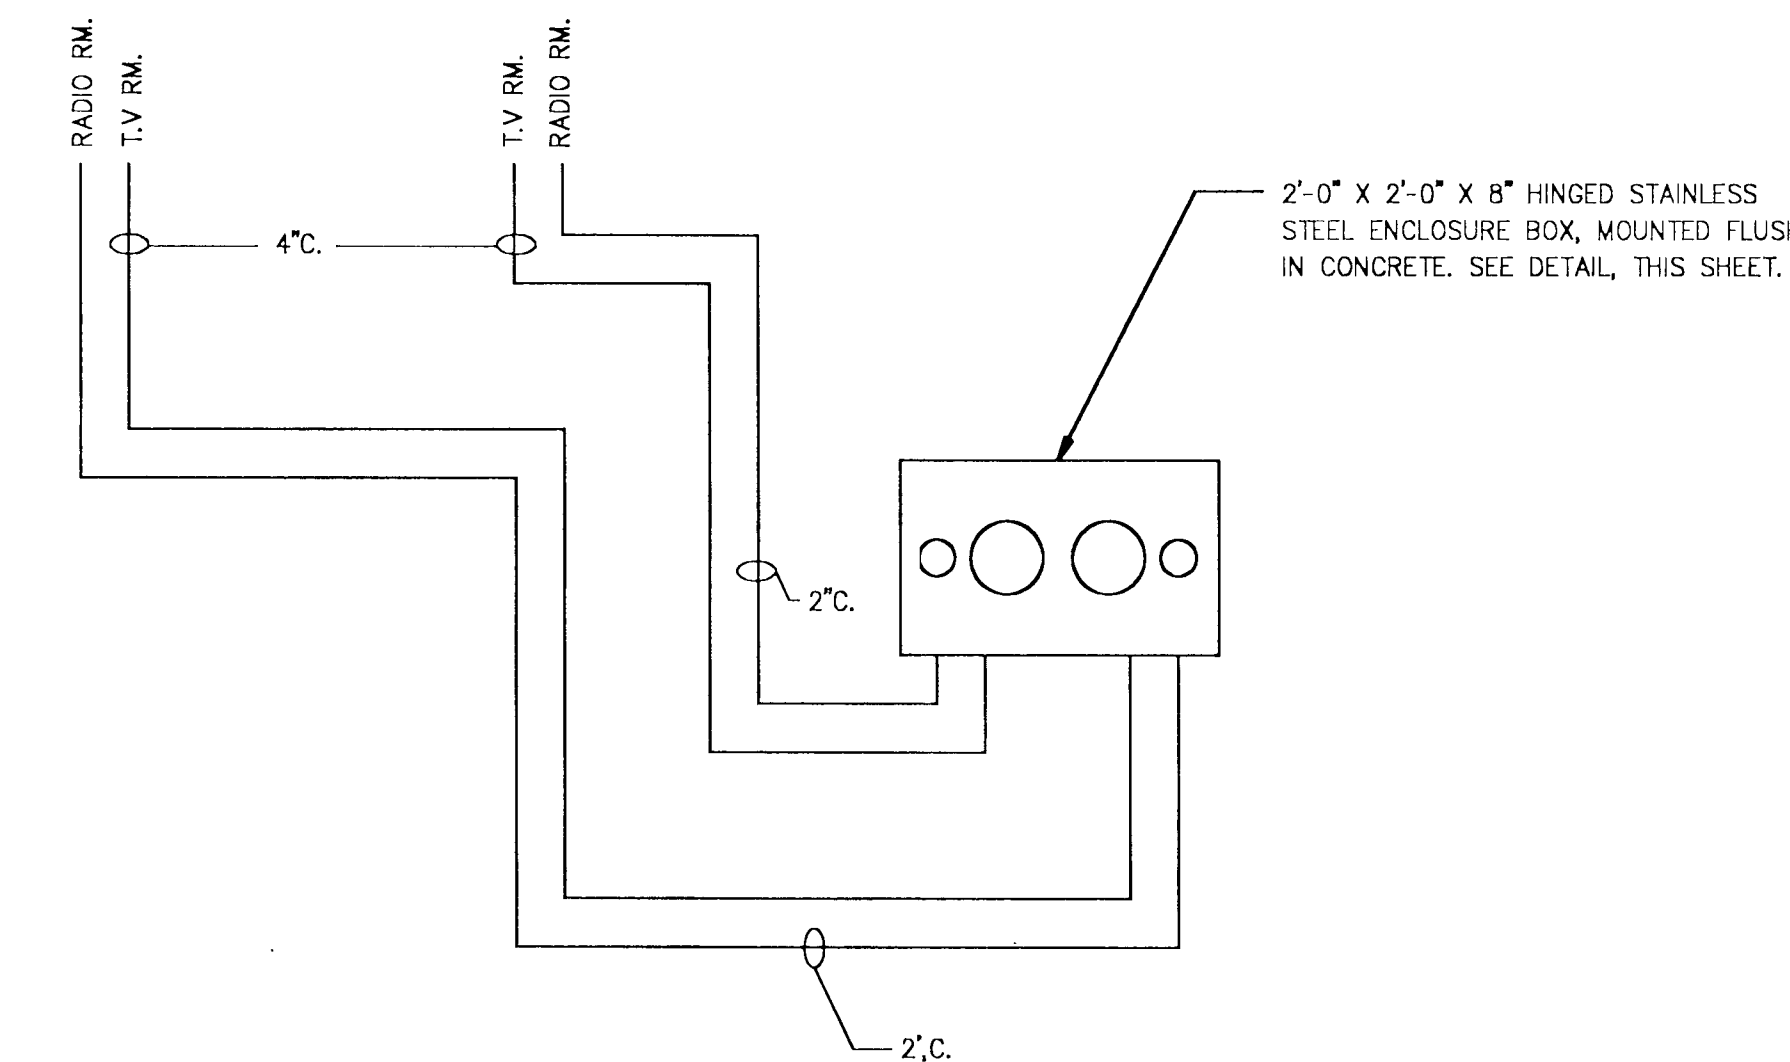

TYPICAL T.V. AND RADIO CONDUIT SYSTEM
N.T.S.

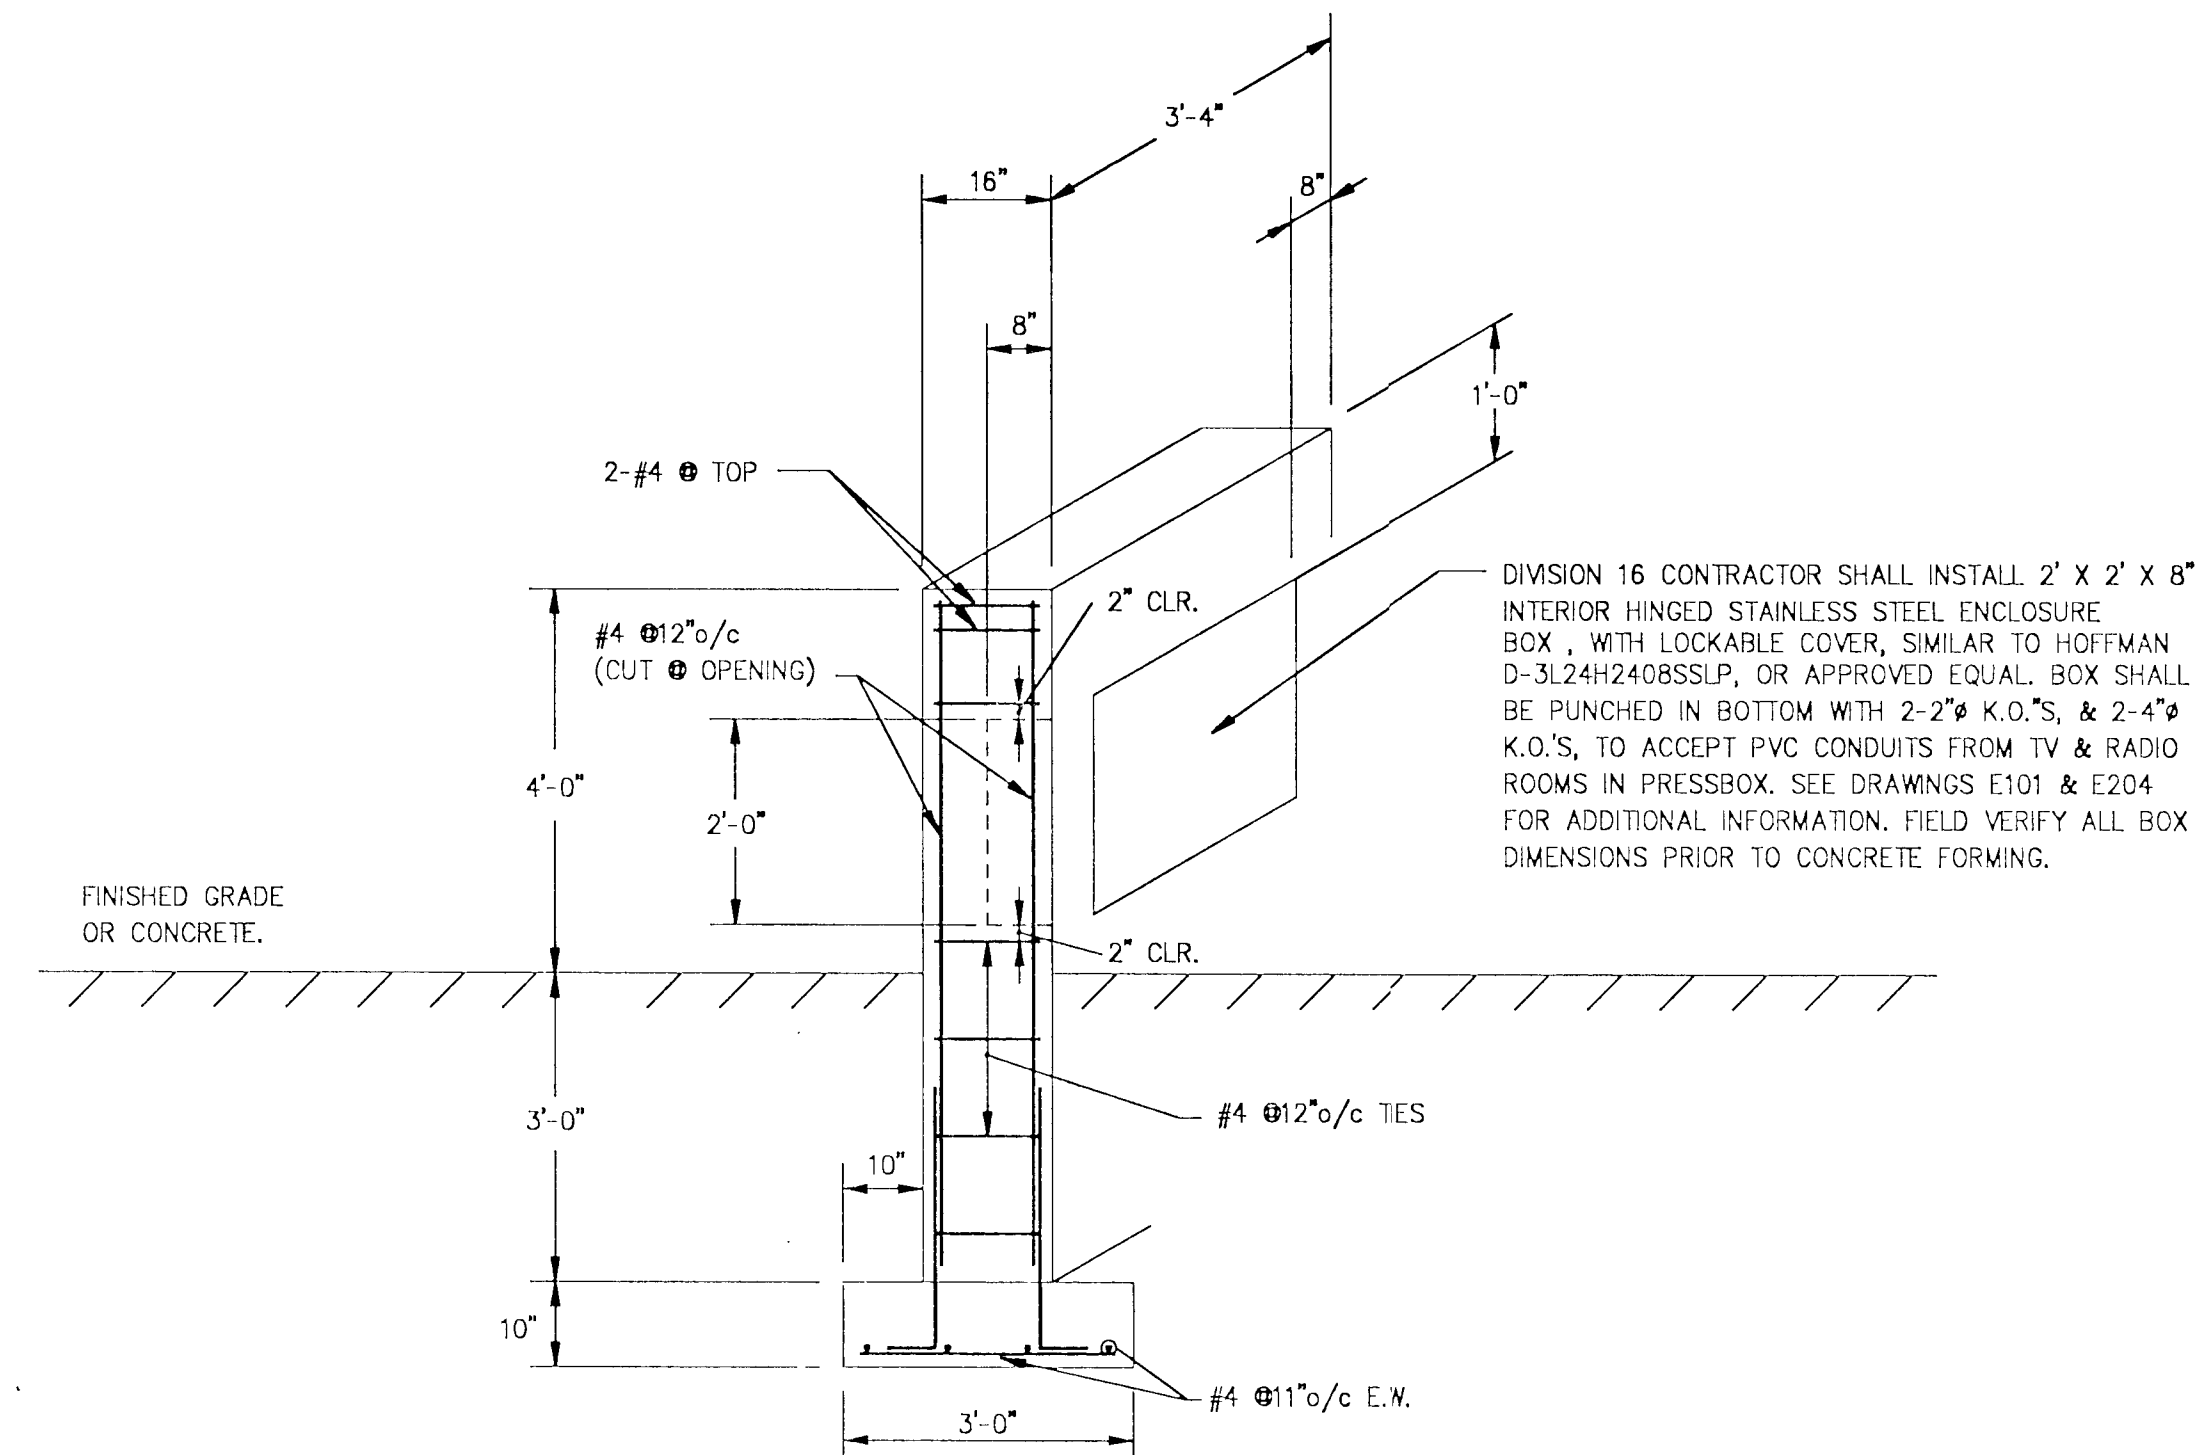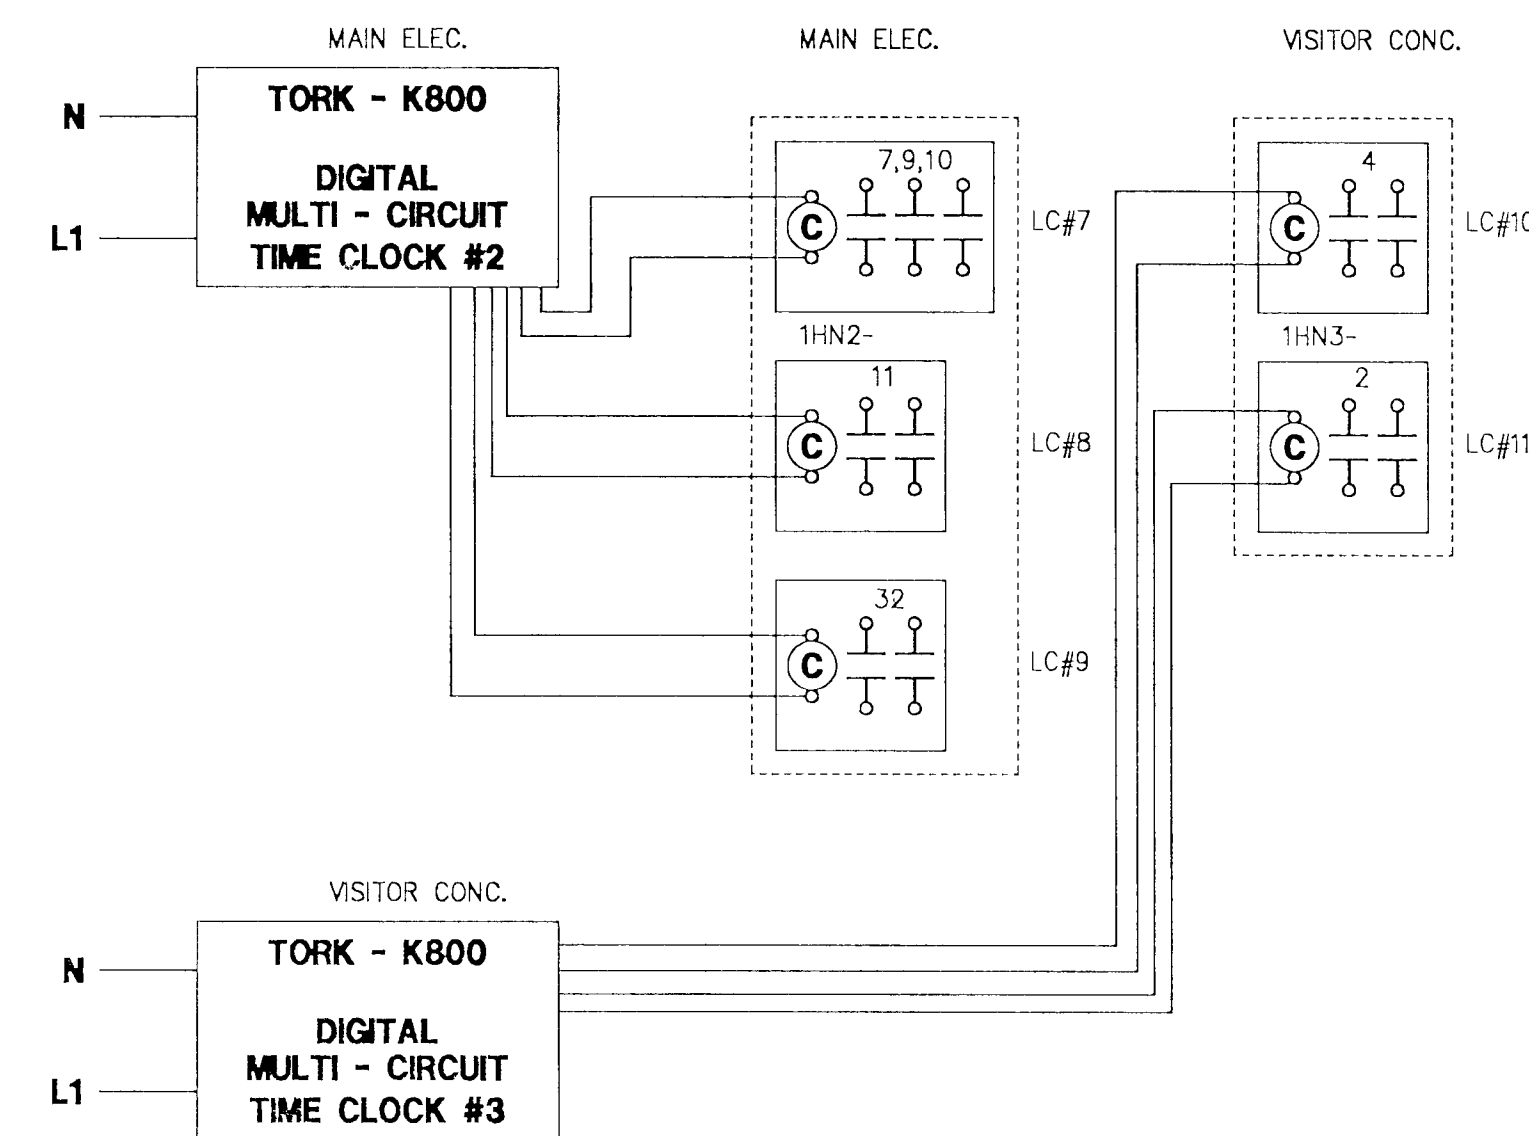

SECTION THRU TYPICAL T.V. AND RADIO CONDUIT SYSTEM AT PARKING AREA
N.T.S.



CERTIFIED
THE ODLE MCGUIRE & SHOOK CORPORATION
ARCHITECTURE - ENGINEERING - LANDSCAPE ARCHITECTURE - INTERIOR DESIGN
8765 NORTH STATE ROAD 37, POST OFFICE BOX 2149, BLOOMINGTON, INDIANA 47402, 812/876-2020
8275 ALISON POINTE TRAIL, POST OFFICE BOX 50428, INDIANAPOLIS, INDIANA 46250, 317/842-0000

REVISIONS
© Copyright 1984 by THE ODLE MCGUIRE & SHOOK CORPORATION. Copyright includes architectural work, building design, plans or drawings, and specifications. Architectural work is the owner's form as well as the engineer's and the architect's. Reproduction without written permission is prohibited.

MICHIGAN CITY SPORTS COMPLEX
AMES FIELD
MICHIGAN CITY, INDIANA

PROJECT NO. 93052
DATE MAY 31, 1984
drawn by: JJC
checked by: RSB

E302
ELECTRICAL
RISER DIAGRAM

F:\ELCDWG\93052\3052E302 05-27-84 10:56:34

TYPE 'Y'

GENERAL DESCRIPTION:
FLUORESCENT, 4 FT, 3 FT, 2 FT, SURFACE MOUNTED ABOVE MIRROR, DIRECT ILLUMINATION, DOWN LIGHT, TWO LAMP.

LAMP:
FLUORESCENT, TWO (2), T-12/MED BI-PIN, 35000K.

BALLAST:
277 VOLT, ENERGY EFFICIENT BALLAST.

CONSTRUCTION:
HOUSING & END PLATE: MIN. 20GA. C.R.S./DIE FORMED. WIRE MAY COVER: MIN. 24GA. C.R.S. SOCKET ASSEMBLY: CAPTIVE LAMP BRACKETS MIN. 18 GA. STEEL.

DIMENSIONS:
3.5 IN. BY 7.75 IN., LENGTH=4 FT.

FINISH:
BAKED ENAMEL, WHITE, FINISH APPLIED AFTER FABRICATION, COLOR TO BE SELECTED BY LIGHTING DESIGNER.

MOUNTING:
SURFACE FLUSH WITH THE BOTTOM OF THE CEILING ON THE WALL.

DIFFUSER:
MIN. THICKNESS=.125 IN., CLEAR, K-12 PATTERN, VIRGIN ACRYLIC.

PHOTOMETRIC DATA:
2 FT. BELOW ON CENTERLINE, 2 FT. FROM WALL: 100 HORIZ. F.C., 3 FT. BELOW ON CENTERLINE, 3 FT. FROM WALL: 51 HORIZ. F.C.

STANDARD:
NULITE BW-240-HRS-277-ELECTRONIC.

APPROVED MFRS.:
ALCO, KLP, NULITE, DAY-BRITE, HUBBELL, PRECISION (PAL), PRUDENTIAL, METALUX.

OMS LIGHT FIXTURE - FM7

TYPE 'K'

GENERAL DESCRIPTION:
INCANDESCENT, RECESSED, DOWN LIGHT ALZAK CONE, ONE LAMP, UL LISTED.

LAMP:
INCANDESCENT, ONE (1), 150 WATT A21.

CONSTRUCTION:
REFLECTOR HOUSING: HEAVY GA., ONE PIECE DIE CAST PLASTER FRAME WITH UNIVERSAL HANGER BRACKETS. HEAT SINK: .070 IN. EXTRUDED ALUMINUM WITH CAST CAP AND SIDE ENTRY CONNECTOR. UNIT PREWIRED WITH FLEX. CONNECTOR AND JUNCTION BOX MOUNTED ON PLASTER FRAME.

MEDIUM BASE SOCKET.

DIMENSIONS:
MAX. HEIGHT = 9 IN., 7 IN. DIAMETER

FINISH:
REFLECTOR CONE: CLEAR, TRIM WHITE.

MOUNTING:
RECESSED, 1/2 IN. NARROW LOW GLASS WHITE TRIM.

REFLECTOR:
0.050 SPECULAR ALZAK

PHOTOMETRIC DATA:
A "C.U." OF AT LEAST 0.85 WITH R.C.R.=1, FLOOR CAVITY REFLECTANCE=20%, CEILING CAVITY REFLECTANCE=80% AND WALL REFLECTANCE=70%.

STANDARD:
INFINITY A60-150.

APPROVED MFRS.:
GOTHAM, KURT VERSEN, LIGHTOLIER, MARCO, PRESCOLITE, CAPRI, HALO, NL.

OMS LIGHT FIXTURE - K4

TYPE 'M'

GENERAL DESCRIPTION:
METAL HALIDE, SPORT LUMINAIRE, POLE MOUNTED, U. LISTD FOR WEATHER PROOF, ONE LAMP WITH VISORS.

LAMP:
METAL HALIDE, ONE (1), 1500 WATT.

BALLAST:
277/480 VOLT, COLD WEATHER.

CONSTRUCTION:
HOUSING: HEAVY GAUGE ALUMINUM, WITH CORROSION RESISTANT HARDWARE, HIGH TEMPERATURE SILICONE GASKETING, SIGHT THROUGH LATCH AIMING. RUNNINON: HEAVY GAUGE STEEL, CORROSION RESISTANT. PROVIDE FUSES, SO CORD, VISORS, CHARCOAL FILTER BREATHER.

DIMENSIONS:
24" HIGH, 20" DEEP.

FINISH:
LEKIROCOTE FINISH.

MOUNTING:
TO BE POLE MOUNTED AS SHOWN.

DIFFUSER DOOR:
STAINLESS STEEL RING WITH SPRING LATCHES.

LENES:
THERMAL SHOCK, IMPACT RESISTANT TEMPERED CLEAR GLASS.

REFLECTOR:
ONE PIECE ALUMINUM PARABOLIC REFLECTOR.

ADDITIONAL NOTES:
POLE SHALL BE .75" HIGH STEEL WITH 100 MPH. WTH BRACKETS, ETC. PROVIDE 4" ROUND BY 20" DEEP CONCRETE BASE WITH REINFORCED STEEL. PROVIDE COMPLETE AIMING LAYOUT. SYSTEM WAS DESIGNED FOR 30 F.C. MAINTAINED.

STANDARD:
HUBBELL SLG-1500H-5-12/13/14/15/16/X-C6-F-CFB-UA-LR-30-4090-4024C-MLS-07031 (75' FOR 100 MPH WIND).

APPROVED MFRS.:
GENERAL ELECTRIC, HI-TEK, HUBBELL, MUSCO- ALTERNATE BID.

OMS LIGHT FIXTURE - MH27

TYPE 'Y'

GENERAL DESCRIPTION:
FLUORESCENT, 1 FT BY 4 FT, SURFACE OR PENDANT, CLOSED TOP INDUSTRIAL, TWO LAMP.

LAMP:
FLUORESCENT, TWO (2), T-12/MEDIUM BI-PIN, 35000K.

BALLAST:
277 VOLT, ENERGY EFFICIENT BALLAST.

CONSTRUCTION:
COLD ROLLED STEEL HOUSING: MIN. 20 GA./DIE FORMED, END PLATES: MIN. 20 GA./DIE FORMED, SOCKET ASSEMBLY: CAPTIVE LAMP BRACKETS (T-12/MEDIUM BI-PIN) /MIN. 19 GA.

DIMENSIONS:
1 FT. BY 4 FT, MAX. HEIGHT = 5.5 IN., MIN. HEIGHT = 4.5 IN.

FINISH:
BAKED ENAMEL, WHITE, FINISH APPLIED AFTER FABRICATION, MIN. REFLECTANCE=85%

MOUNTING:
SURFACE ON THE CEILING, PENDANT BUT FLUSH WITH THE BOTTOM OF THE JOIST.

REFLECTOR:
COLD ROLLED STEEL, MIN. 24 GA., DIE FORMED, ROLLED EDGES, CLOSED TOP

STANDARD:
HUBBELL HQ-42R-PA10-E4-277-ELECTRONIC.

APPROVED MFRS.:
DAY-BRITE, HUBBELL, KLP, KEYSTONE, METALUX, WILLIAMS, LITHONIA.

OMS LIGHT FIXTURE - FM5

TYPE 'E'

GENERAL DESCRIPTION:
LIGHT EMITTING DIODE POWERED EXIT LIGHT. REFER TO E SERIES DRAWINGS FOR LEFT/RIGHT, SINGLE OR DOUBLE ARROW.

LAMP:
ILLUMINATION RESISTANT LIGHT EMITTING DIODE LIGHT SOURCE WITH 80 YEAR LAMP LIFE.

BALLAST:
120/277 DUAL.

CONSTRUCTION:
HOUSING: PRECISION MOLDED, DIE-CAST ALUMINUM WITH FULLY OVERLAPPING LIGHT SEALS AND NO LIGHT LEAKS. BRUSHED ALUMINUM FACEPLATE. POLYCARBONATE FACE SHIELD. UNIVERSAL DIRECTIONAL ARROW. KNOCKOUTS. HIGHED FACEPLATE WITH SPRING LATCHES.

DIMENSIONS:
HEIGHT = 7.5", WIDTH = 12", DEPTH = 3", FACE DEPTH = 1-3/4", LETTER HEIGHT = 6" W/ 3/4" STROKE.

FINISH:
FINISH TO BE WHITE W/GREEN LETTERS.

MOUNTING:
SURFACE MOUNTED. REFER TO DRAWINGS FOR CEILING OR WALL MOUNT.

ADDITIONAL NOTES:
PROVIDE A 1-2 IN HIGH CANOPY, FOR CEILING MOUNTED UNITS.

STANDARD:
HUBBELL #LED-1-EM-G-W-W

APPROVED MFRS.:
HUBBELL, GILBERT, SAUNDERS-ROE, ISOLITE, SURELITE.

OMS LIGHT FIXTURE - E4

TYPE 'M'

GENERAL DESCRIPTION:
HIGH INTENSITY DISCHARGE, POST TOP MOUNTED LUMINAIRE, UL LISTED WET LOCATIONS, WITH SPECIAL SHAPE, APPEARANCE AND PERFORMANCE.

LAMP:
MOGUL BASE, CLEAR, ED17 SHAPE, METAL HALIDE, ONE LAMP, 175 WATT, CLEAR.

BALLAST:
277 VOLT, -20 DEGREE COLD WEATHER RATED, HIGH POWER FACTOR CORE AND COLD, INTEGRALLY MOUNTED IN FIXTURE.

CONSTRUCTION:
CAST IRON AND CAST ALUMINUM FITTERS AND CASINGS.

DIMENSIONS:
HEIGHT=41 IN., DIAMETER=18 IN.

FINISH:
PRIME PAINT FACTORY APPLIED. FINISH COAT FIELD INSTALLED.

MOUNTING:
POST TOP MOUNTED ON "ONE PIECE CAST IRON" POLE. LIGHT CENTER 14'-0" ABOVE BASE OF POLE.

LENES:
INJECTION MOLDED REFRACTIVE PRISMATIC POLYCARBONATE, WITH HYDROFORMED REFLECTOR AND ASYMMETRIC TYPE III DISTRIBUTION. FINAL MOUNTED ON TOP.

ADDITIONAL NOTES:
EACH APPROVED MFR. MUST SUBMIT A SAMPLE FIXTURE AND POLE FOR ENGINEER/OWNER REVIEW.

STANDARD:
SPRING CITY # WASHINGTON - 118 REFRACTIVE GLOBE W/FINAL.

APPROVED MFRS.:
ANTIQUE STREET LAMPES, STERNBERG, HADCO, SPRING CITY, TRIMBLE HOUSE, VESCO.

OMS LIGHT FIXTURE - M22

TYPE 'M'

GENERAL DESCRIPTION:
H.P.S., WALLLIGHTER, SURFACE MOUNT, ONE LAMP, UL FOR WET LOCATIONS.

LAMP:
HIGH PRESSURE SODIUM, 175 WATT, E-17, MEDIUM BASE.

BALLAST:
277 VOLT, LOW TEMP.

CONSTRUCTION:
LENS FRAME: DIE-CAST ALUMINUM. BACK PLATE: DIE-CAST ALUMINUM WITH GASKETED RAIN SHIELD. LENS FRAME GASKET: LIQUID SILICONE RUBBER/ PERMANENT ADHESION/ INTERFACE BETWEEN LENS FRAME AND BACK PLATE. SOCKET: GLAZED PORCELAIN/ MOGUL BASE. VANDAL RESISTANT SCREWS.

DIMENSIONS:
MAX. WIDTH=15 IN., MAX. DEPTH=8 IN, MAX. HEIGHT=14 IN.

FINISH:
FINISH TO BE BRONZE LEKIROCOTE.

MOUNTING:
WALL MOUNTED, SEE A SERIES DRAWINGS FOR HEIGHT.

REFLECTOR:
REFLECTOR-REFLECTOR COMBINATION. REFLECTOR: ASYMMETRIC DESIGN/ SPHERICAL ANODIZED ALUMINUM. REFRACTOR: ONE PIECE/ WRAP-AROUND/ BOROSILICATE/ BONDED TO LENS FRAME/ PRISMATIC INNER AND OUTER SURFACES.

STANDARD:
HUBBELL PVL-0175H-118-F-TR.

APPROVED MFRS.:
BENJAMIN, GENERAL ELECTRIC CO., HI-TEK, HUBBELL, LUMARK, McGRAW-EDISON, CL.

OMS LIGHT FIXTURE - MS3

TYPE 'Y'

GENERAL DESCRIPTION:
FLUORESCENT, SURFACE MOUNT, U.L. LISTED FOR WET LOCATION, FOUR FEET, TWO LAMP.

LAMP:
FLUORESCENT, TWO (2), T-12/MEDIUM BI-PIN, 35000K.

BALLAST:
277 VOLT, ENERGY EFFICIENT BALLAST.

CONSTRUCTION:
HOUSING: STEEL/CONTINUOUS WELDED SEAM. LATCH HINGE: STAINLESS STEEL COVER

PLATE: STEEL/FORMED. DRIP EDGE FLANGE FOR POSITIVE SEATING AND GASKETING.

MITERED
ENCLOSURE DOOR FRAME: FORMED ALUMINUM WITH DIE-CAST RIGIDIZERS AT CORNERS/HINGED EITHER SIDE.

DIMENSIONS:
WIDTH=9 IN., LENGTH=51 IN., HEIGHT=4.5 IN.

FINISH:
PORCELAIN ENAMEL FINISH.

MOUNTING:
SURFACE MOUNT ON THE CEILING, SECURE FIXTURE TO CEILING GRID COMPLETE WHEN REQUIRED, PROVIDE SUPPORTS FROM FIXTURE TO BUILDING STRUCTURE, PROVIDE PENDANT SUPPORT IN EXPOSED AREAS.

DIFFUSER:
MIN. THICKNESS=.125 IN., CLEAR SMOOTH K-12.

PHOTOMETRIC DATA:
A "C.U." OF AT LEAST .76 WITH R.C.R.=1, FLOOR CAVITY REFLECTANCE=20%, CEILING CAVITY REFLECTANCE=80% AND WALL REFLECTANCE=70%.

STANDARD:
NULITE DW-240R500-277V.

APPROVED MFRS.:
COLUMBIA, DAY-BRITE, HUBBELL, KLP, METALUX, MARK, WILLIAMS.

OMS LIGHT FIXTURE - FM5

TYPE 'F'

GENERAL DESCRIPTION:
FLUORESCENT, 5" BY 7", RECESSED MOUNTED (IN WALL) STEP LIGHT. ASYMMETRIC FORWARD DISTRIBUTION, UL LISTED WET LOCATION.

LAMP:
FLUORESCENT, ONE LAMP PL13, 13 WATT.

BALLAST:
277 VOLT.

CONSTRUCTION:
HOUSING: MIN. 18GA. GALVANIZED STEEL. FRONT: CAST ALUMINUM.

DIMENSIONS:
HEIGHT=6 IN., DEPTH=4 IN., WIDTH=13 IN.

FINISH:
FRONT: ANTI-CORROSIVE ALUMINUM. HOUSING: ASPHALTIC COATING ON EXTERIOR/BAKED ENAMEL (WHITE) INTERIOR.

MOUNTING:
RECESS IN WALL, HEIGHT TO BE DETERMINED BY ARCHITECT.

LENES:
IMPACT RESISTANT GLASS WITH GASKET.

STANDARD:
LIGHTTECH INC. SL-8120-F-PL13-G-W-F227V.

APPROVED MFRS.:
ALCO, COLE, LIGHT TEC, PRESCOLITE.

OMS LIGHT FIXTURE - FM12

TYPE 'M'

GENERAL DESCRIPTION:
HIGH INTENSITY DISCHARGE, FLOOD LIGHT BRACKET MOUNTED, ONE LAMP, UL LISTED FOR WET LOCATION.

LAMP:
METAL HALIDE, ONE 175 WATT COATED, BT-37, INIT, LUMENS 14000.

BALLAST:
277 VOLT, COLD WEATHER.

CONSTRUCTION:
DIE CAST ALUMINUM HOUSING WITH REMOVABLE GASKETED REAR HOUSING FOR RELAMPING ACCESS. TRUNNION MOUNTING.

DIMENSIONS:
WIDTH =14IN., HEIGHT =9IN.

FINISH:
DARK BRONZE.

MOUNTING:
POLE MOUNTED ON BRACKETS.

LENES:
THERMAL SHOCK AND HIGH-IMPACT RESISTANT CLEAR GLASS LENS SEALED TO FIXTURE DOOR BY CONTINUOUS SILICONE GASKET.

REFLECTOR:
HYDROFORMED ALUMINUM PARABOLIC REFLECTOR WITH DIFFUSE FINISH.

ADDITIONAL NOTES:
PROVIDE 3FT. 16/3 SO CORD PREWIRED AND SINGLE FUSE.

PHOTOMETRIC DATA:
IES/NEMA TYPE AS NEEDED.

STANDARD:
HUBBELL MHS-0175H-268-4090-4024C-4944.

APPROVED MFRS.:
GENERAL ELECTRIC CO., HI-TEK, HUBBELL, LUMARK, McGRAW-EDISON.

OMS LIGHT FIXTURE - MS5

TYPE 'M'

GENERAL DESCRIPTION:
H.P.S., WALLLIGHTER, SURFACE MOUNT, ONE LAMP, UL FOR WET LOCATIONS.

LAMP:
HIGH PRESSURE SODIUM, 175 WATT, E-17, MEDIUM BASE.

BALLAST:
277 VOLT, LOW TEMP.

CONSTRUCTION:
LENS FRAME: DIE-CAST ALUMINUM. BACK PLATE: DIE-CAST ALUMINUM WITH GASKETED RAIN SHIELD. LENS FRAME GASKET: LIQUID SILICONE RUBBER/ PERMANENT ADHESION/ INTERFACE BETWEEN LENS FRAME AND BACK PLATE. SOCKET: GLAZED PORCELAIN/ MOGUL BASE. VANDAL RESISTANT SCREWS.

DIMENSIONS:
MAX. WIDTH=15 IN., MAX. DEPTH=8 IN, MAX. HEIGHT=14 IN.

FINISH:
FINISH TO BE BRONZE LEKIROCOTE.

MOUNTING:
WALL MOUNTED, SEE A SERIES DRAWINGS FOR HEIGHT.

REFLECTOR:
REFLECTOR-REFLECTOR COMBINATION. REFLECTOR: ASYMMETRIC DESIGN/ SPHERICAL ANODIZED ALUMINUM. REFRACTOR: ONE PIECE/ WRAP-AROUND/ BOROSILICATE/ BONDED TO LENS FRAME/ PRISMATIC INNER AND OUTER SURFACES.

STANDARD:
HUBBELL PVL-0175H-118-F-TR.

APPROVED MFRS.:
BENJAMIN, GENERAL ELECTRIC CO., HI-TEK, HUBBELL, LUMARK, McGRAW-EDISON, CL.

OMS LIGHT FIXTURE - MS3

TYPE 'Y'

GENERAL DESCRIPTION:
FLUORESCENT, 2FT BY 4FT, GRID, LAY-IN, THREE LAMPS, UL LISTED, WET LOCATION.

LAMP:
FLUORESCENT, THREE LAMPS, T-12/ MED BI-PIN, 35000K.

BALLAST:
277 VOLT, ENERGY EFFICIENT, DUAL SWITCHING.

CONSTRUCTION:
HOUSING: MIN. 20GA. C.R.S./DIE FORMED/ONE PIECE/FULL LENGTH STIFFENERS. END PLATES: MIN. 20 GA. C.R.S. WIRE WAY COVER: MIN. 24 GA. C.R.S. SOCKET ASSEMBLY: CAPTIVE LAMP BRACKETS (5-12/ MEDIUM BI-PIN)/ MIN. 18 GA. STEEL.

DIMENSIONS:
2FT X 4FT, MAX HEIGHT = 5 IN. MIN HEIGHT = 4.25 IN.

FINISH:
BAKED ENAMEL, WHITE, FINISH APPLIED AFTER FABRICATION, MIN. REFLECTANCE = 85%

MOUNTING:
LAY-IN, SECURE FIXTURE TO BUILDING STRUCTURE.

DIFFUSER DOOR:
ALUMINUM, FLAT MITERED CORNERS, T-TYPE HINGES, HINGED EITHER SIDE, POSITIVE CAM ACTION LATCHES.

DIFFUSER:
MIN. THICKNESS = .125 IN., CLEAR, K-12 PATTERN, VIRGIN ACRYLIC.

PHOTOMETRIC DATA:
A "C.U." OF AT LEAST .68 WITH R.C.R.=1, FLOOR CAVITY REFLECTANCE=20%, CEILING CAVITY REFLECTANCE=80% AND WALL REFLECTANCE=70%.

STANDARD:
FAIL-SAFE CTO-24-3-40-1P12-ALP-ESB.

APPROVED MFRS.:
COLUMBIA, HUBBELL, KLP, FAIL-SAFE, WILLIAMS, DAY-BRITE, LITHONIA.

OMS LIGHT FIXTURE - FL14

TYPE 'F'

GENERAL DESCRIPTION:
FLUORESCENT, HIGH ABUSE, WALL MOUNT, UL LISTED FOR WET LOCATION.

LAMP:
FLUORESCENT, TWO (2), TWIN TUBE 2PL13.

BALLAST:
277 VOLT, HPF.

CONSTRUCTION:
HOUSING: IMPACT RESISTANT POLYCARBONATE HOUSING WITH TAMPERPROOF SCREWS.

DIMENSIONS:
BASE: ONE PIECE CAST ALUMINUM MOUNTING BASE.

DIMENSIONS:
14" WIDE BY 7" HIGH BY 4" DEEP.

FINISH:
BENJAMIN MOORE 602 (SPECIAL).

MOUNTING:
WALL MOUNT.

DIFFUSER:
IMPACT RESISTANT POLYCARBONATE PRISMATIC LENS.

STANDARD:
FAIL SAFE FSS-W-2/13-277-9311.

APPROVED MFRS.:
FAIL-SAFE VANDAL PROOF, KENALL, MARK, MORELITE, NORTHERN LITE.

OMS LIGHT FIXTURE - H/FS9

TYPE 'M'

GENERAL DESCRIPTION:
HIGH INTENSITY DISCHARGE, RECESSED, 8", OPEN APERTURE DOWNLIGHT, WITH LENS, ONE LAMP, UL LISTED.

LAMP:
METAL HALIDE, COATED, ONE (1), 75 WATT ED17, MED. BASE, M101, INIT, LUMENS 5200, C.R.I. 65.

BALLAST:
277 VOLT DUAL, ENCASED AND POTTED.

CONSTRUCTION:
HOUSING: MIN. 20 GA. C.R.S. FRAME: MIN. 16 GA. GALVANIZED STEEL, DIE-FORMED. LAMP SOCKET: MOGUL BASE IN EXTRUDED ALUMINUM HEAT SINK. BALLAST & SPLICE BOX ACCESSIBLE FROM BELOW THE CEILING, WITH 2-27 IN. MOUNTING BARS.

DIMENSIONS:
MAX. RECESSED HEIGHT = 11", TRIM DIAMETER 8".

FINISH:
TRIM WHITE.

MOUNTING:
RECESSED WITH PROVISIONS FOR MOUNTING IN PLASTER, DRYWALL OR GRID CEILING, PROVIDE SUPPORT AS NEEDED.

LENES:
RECESSED GLASS LENS, LOWER MATE BLACK REFLECTOR.

REFLECTOR:
UPPER CLEAR ALZAK, LOWER MATE BLACK.

PHOTOMETRIC DATA:
A "C.U." OF AT LEAST .69 WITH R.C.R.=1, FLOOR CAVITY=20%, CEILING CAVITY=80% AND WALL REFLECTANCE=70%.

STANDARD:
INFINITY MH75-70-F.

APPROVED MFRS.:
GOTHAM, HALO, KURT VERSEN, MARCO, N/L, PRESCOLITE, INFINITY, KIRLIN.

OMS LIGHT FIXTURE - MH10

TYPE 'M'

GENERAL DESCRIPTION:
GOTHIC STYLE LUMINAIRE WITH ALUMINUM 8 SIDED HOUSING, OPAQUE GLASS LENSES, AND GASKETED GLASS UP/DN OPENINGS. FIXTURE TO BE WALL MOUNTED.

LAMP:
METAL HALIDE 400 WATT CLEAR.

DIMENSIONS:
WIDTH=15", HEIGHT=42"

STANDARD:
STERNER GY-42-BB-400H-277-

FINISH:
BENJAMIN MOORE 602

ADDITIONAL NOTES:
ALLOWANCE FOR TYPE 'M6' FIXTURE IS \$1100 EACH.

OMS LIGHT FIXTURE - MH14

OMS LIGHT FIXTURE - MS3

TYPE 'Y(c)'

GENERAL DESCRIPTION:
FLUORESCENT, 2FT BY 4FT, GRID LAY-IN, STATIC, THREE LAMPS, UL LISTED.

LAMP:
FLUORESCENT, THREE LAMPS, T-12/ MED BI-PIN, 35000K.

BALLAST:
277 VOLT, ENERGY EFFICIENT, DUAL SWITCHING.

CONSTRUCTION:
HOUSING: MIN. 22GA. C.R.S./DIE FORMED/ONE PIECE/FULL LENGTH STIFFENERS. END PLATES: MIN. 20 GA. C.R.S. WIRE WAY COVER: MIN. 24 GA. C.R.S. SOCKET ASSEMBLY: CAPTIVE LAMP BRACKETS (T-12/ MEDIUM BI-PIN)/ MIN. 18 GA. STEEL.

DIMENSIONS:
2FT X 4FT, MAX HEIGHT = 5 IN. MIN HEIGHT = 4.25 IN.

FINISH:
BAKED ENAMEL, WHITE, FINISH APPLIED AFTER FABRICATION, MIN. REFLECTANCE = 85%

MOUNTING:
GRID LAY-IN, SECURE FIXTURE TO STRUCTURE.

DIFFUSER DOOR:
ALUMINUM, FLAT MITERED CORNERS, T-TYPE HINGES, HINGED EITHER SIDE, POSITIVE CAM ACTION LATCHES.

DIFFUSER:
MIN. THICKNESS = .125 IN., CLEAR, K-12 PATTERN, VIRGIN ACRYLIC.

PHOTOMETRIC DATA:
A "C.U." OF AT LEAST .68 WITH R.C.R.=1, FLOOR CAVITY REFLECTANCE=20%, CEILING CAVITY REFLECTANCE=80% AND WALL REFLECTANCE=70%.

STANDARD:
HUBBELL HQ30NCD02-S4-C-277-EQ

APPROVED MFRS.:
COLUMBIA, HUBBELL, KLP, METALUX, WILLIAMS, DAY-BRITE, LITHONIA.

ADDITIONAL NOTES:
(c) DENOTES A FLANGED FIXTURE WITH FIRE RATED ENCLOSURE TO BE MOUNTED IN FIRE RATED CEILING.

OMS LIGHT FIXTURE - FL1

TYPE 'F'

GENERAL DESCRIPTION:
FLUORESCENT, 4FT, SURFACE, MAXIMUM SECURITY, TWO LAMPS, UL LISTED WET LOCATION.

LAMP:
FLUORESCENT, TWO (2), T-12/MED BI-PIN, 35000K.

BALLAST:
120 VOLT. ELECTRONIC BALLAST.

CONSTRUCTION:
HOUSING: CRS 16GA. C.R.S. BACK PLATE: MIN. 16GA. C.R.S./ONE-PIECE

WIREWAY:
MIN. 18GA. C.R.S., MIN. SIX TAMPERPROOF SCREWS SECURING DIFFUSER TO BACKPLATE, SOCKET ASSEMBLY: CAPTIVE LAMP BRACKETS (T-12/MEDIUM BI-PIN)/MIN. 18GA. C.R.S.

DIMENSIONS:
2" WIDE BY 48" LONG AND 14" HIGH.

FINISH:
BAKED ENAMEL, WHITE, OVER CORROSION RESISTANT COATING.

MOUNTING:
WALL MOUNT.

DIFFUSER DOOR:
DIE FORMED MIN. 16GA. C.R.S.

DIFFUSER:
.25" CLEAR POLYCARBONATE.

STANDARD:
NORTHERN SWT-D-1-24R-7/CW-WL/277.

APPROVED MFRS.:
FAIL-SAFE VANDAL PROOF, KENALL, MARK, MORELITE, NORTHERN LITE, VERSA-TECH.

FIXTURE - H/FS6

OMS LIGHT

TYPE 'K'

GENERAL DESCRIPTION:
INCANDESCENT, SURFACE, VAPORITE, SCREW-ON GLOBE & GUARD, ONE LAMP.

LAMP:
INCANDESCENT, ONE (1), 100 WATT, A19 IF.

CONSTRUCTION:
BODY: DIE-CAST ALUMINUM. GUARD: DIE-CAST ALUMINUM.

FINISH:
DIE-CAST ALUMINUM.

MOUNTING:
SURFACE, SEE DWG(S) FOR WALL OR CEILING MOUNT.

LENES:
GLOBE GLASS.

STANDARD:
KEENE VOX-111 SERIES.

APPROVED MFRS.:
BENJAMIN, CROUSE HNDs, KEENE-STONCO, MARCO, HUBBELL.

OMS LIGHT FIXTURE - K1

TYPE 'M'

GENERAL DESCRIPTION:
GOTHIC STYLE LUMINAIRE WITH ALUMINUM 8 SIDED HOUSING, OPAQUE GLASS LENSES, AND GASKETED GLASS UP/DN OPENINGS. FIXTURE TO BE WALL MOUNTED.

LAMP:
METAL HALIDE 400 WATT CLEAR.


DIMENSIONS:
WIDTH=15", HEIGHT=42"

STANDARD:
STERNER GY-42-BB-400H-277-

FINISH:
BENJAMIN MOORE 602

ADDITIONAL NOTES:
ALLOWANCE FOR TYPE 'M5' FIXTURE IS \$1350 EACH.

OMS LIGHT FIXTURE - MH14

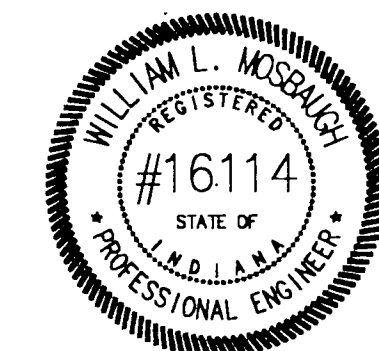CERTIFIED
William L. McGuire

THE ODLE MCGUIRE & SHOOK CORPORATION
ARCHITECTURE • ENGINEERING • LANDSCAPE ARCHITECTURE • INTERIOR DESIGN

6795 NORTH STATE ROAD 37, POST OFFICE BOX 2746, BLOOMINGTON, INDIANA 47402 812/796-2000
8275 ALISON FORTNE TRAIL, POST OFFICE BOX 3069, INDIANAPOLIS, INDIANA 46250 317/942-0000

REVISIONS

© Copyright 1994 by THE ODLE MCGUIRE & SHOOK CORPORATION. Copyright includes architectural work, building design, plans or drawings, and specifications. Architectural work is the mental term as well as the arrangement and composition of space and elements in the design. Reproduction without written permission is prohibited.

MICHIGAN CITY SPORTS COMPLEX
AMES FIELD
MICHIGAN CITY, INDIANA

PROJECT NO. 93052

DATE MAY 31, 1994

drawn by: JUC

checked by: RSB

E303LIGHT FIXTURE
SCHEDULE

JOB NAME: AMES MAIN: MINOR: C/F/USH MINEMA 1 LOCATION: 33052									
JOB NO: 93052									
PANEL	AMP	VOLT	# W BILGUS	CLIFE	DOUBBLE	ENEMA	3R NOTES		
1HN1	200	120	1480	3.4					
DESCRIPTION	OR. POLE	TRIP	LITE	EQUIP	HEAT	# A/C	# FUR	POLE	TRIP
1									
2									
3									
4									
5									
6									
7									
8									
9									
10									
11									
12									
13									
14									
15									
16									
17									
18									
19									
20									
21									
22									
23									
24									
25									
26									
27									
28									
29									
30									
31									
32									
33									
34									
35									
36									
37									
38									
39									
40									
41									
42									


JOB NAME: AMES MAIN: MINOR: C/F/USH MINEMA 1 LOCATION: 33052									
JOB NO: 93052									
PANEL	AMP	VOLT	# W BILGUS	CLIFE	DOUBBLE	ENEMA	3R NOTES		
2LN1	125	120	1208	3.4					
DESCRIPTION	OR. POLE	TRIP	LITE	EQUIP	HEAT	# A/C	# FUR	POLE	TRIP
1									
2									
3									
4									
5									
6									
7									
8									
9									
10									
11									
12									
13									
14									
15									
16									
17									
18									
19									
20									
21									
22									
23									
24									
25									
26									
27									
28									
29									
30									
31									
32									
33									
34									
35									
36									
37									
38									
39									
40									
41									
42									

JOB NAME: AMES MAIN: MINOR: C/F/USH MINEMA 1 LOCATION: 33052									
JOB NO: 93052									
PANEL	AMP	VOLT	# W BILGUS	CLIFE	DOUBBLE	ENEMA	3R NOTES		
2LN2	125	120	1208	3.4					
DESCRIPTION	OR. POLE	TRIP	LITE	EQUIP	HEAT	# A/C	# FUR	POLE	TRIP
1									
2									
3									
4									
5									
6									
7									
8									
9									
10									
11									
12									
13									
14									
15									
16									
17									
18									
19									
20									
21									
22									
23									
24									
25									
26									
27									
28									
29									
30									
31									
32									
33									
34									
35									
36									
37									
38									
39									
40									
41									
42									

JOB NAME: AMES MAIN: MINOR: C/F/USH MINEMA 1 LOCATION: 33052									
JOB NO: 93052									
PANEL	AMP	VOLT	# W BILGUS	CLIFE	DOUBBLE	ENEMA	3R NOTES		
2LN1	200	120	1480	3.4					
DESCRIPTION	OR. POLE	TRIP	LITE	EQUIP	HEAT	# A/C	# FUR	POLE	TRIP
1									
2									
3									
4									
5									
6									
7									
8									
9									
10									
11									
12									
13									
14									
15									
16									
17									
18									
19									
20									
21									
22									
23									
24									
25									
26									
27									
28									
29									
30									
31									
32									
33									
34									
35									
36									
37									
38									
39									
40									
41									
42									




DISTRIBUTION PANELBOARD				
ID. LABEL: HDPI PROJECT NO. 33052				
MAINS: 400 AMPS. TYPE: MAIN LUGS ONLY				
EQUIPMENT: 25,000 A.L.C. R.M.S. SYM. RATING				
ENCLOSURE: NEMA 1 MOUNTING: TOP FED BOTTOM FED				
NEMA 3R FLUSH FEEDER: RUN(S).				
NEMA SURFACE RUN(S).				
BRANCH BREAKER	DESIG.	SIZE	EQUIPMENT OR LOAD SERVED	NOTES
1	200	3	1LN1	33
2	125	3	1LN2	12
3	125	3	2LN1	23
4	100	3	SPARE	
5	60	3		
6	40	3		
7	30	3		

JOB NAME: AMES MAIN: MINOR: C/F/USH MINEMA 1 LOCATION: 33052									
JOB NO: 93052									
PANEL	AMP	VOLT	# W BILGUS	CLIFE	DOUBBLE	ENEMA	3R NOTES		
2LN3	100	120	1480	3.4					
DESCRIPTION	OR. POLE	TRIP	LITE	EQUIP	HEAT	# A/C	# FUR	POLE	TRIP
1									
2									
3									
4									
5									
6									
7									
8									
9									
10									
11									
12									
13									
14									
15									
16									
17									
18									

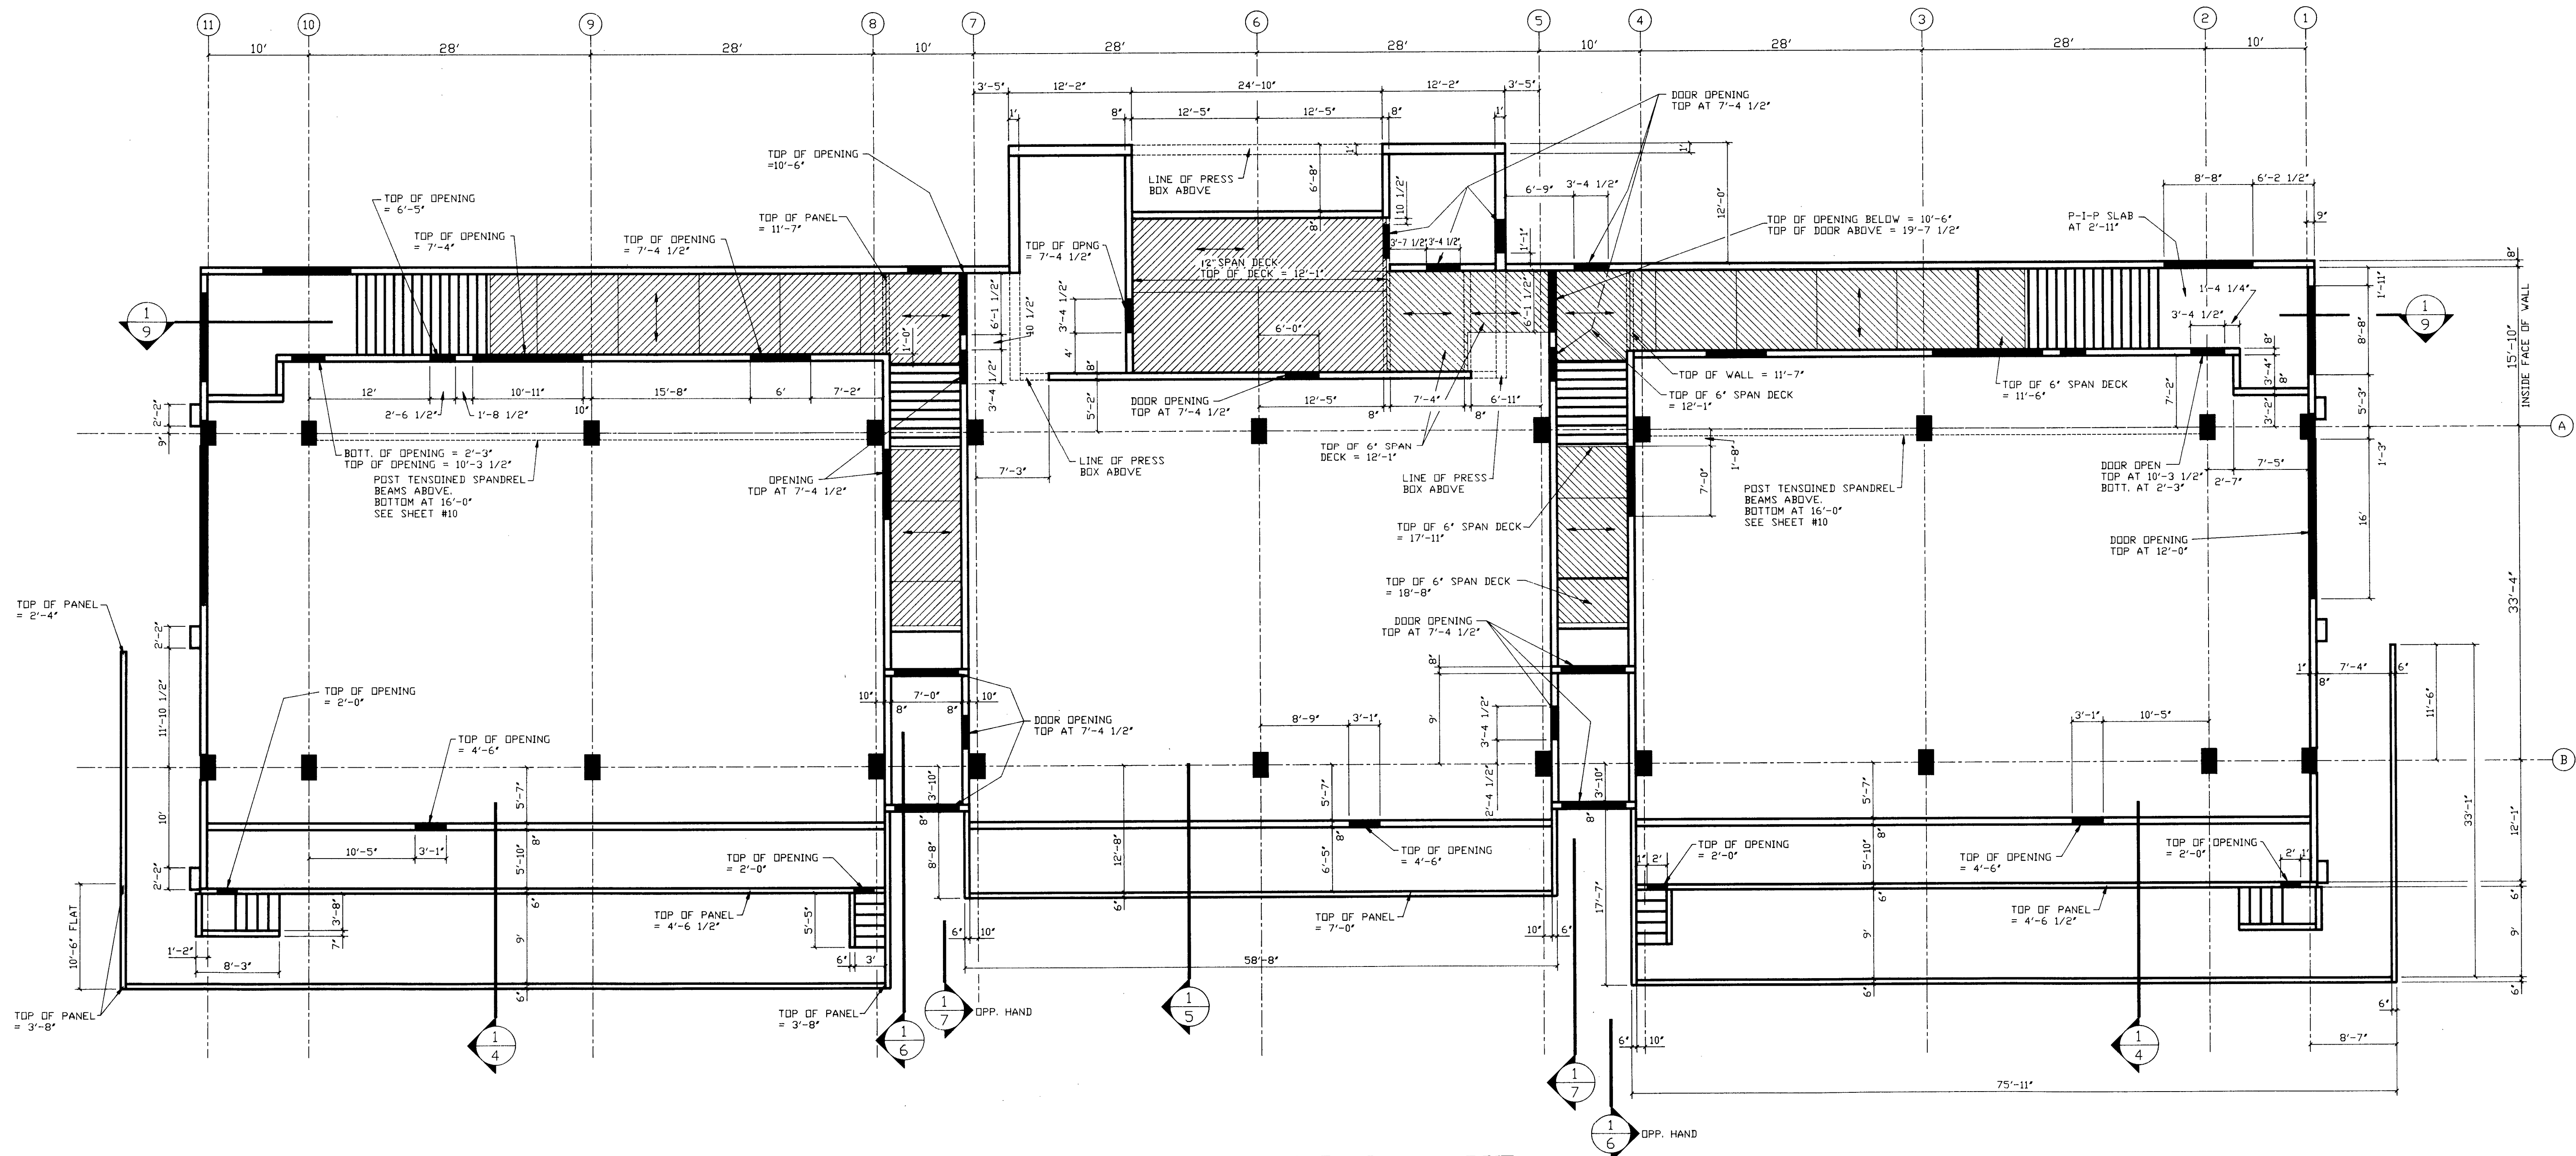

PRECAST PANEL LAYOUT

SCALE 1/8" = 1'-0"

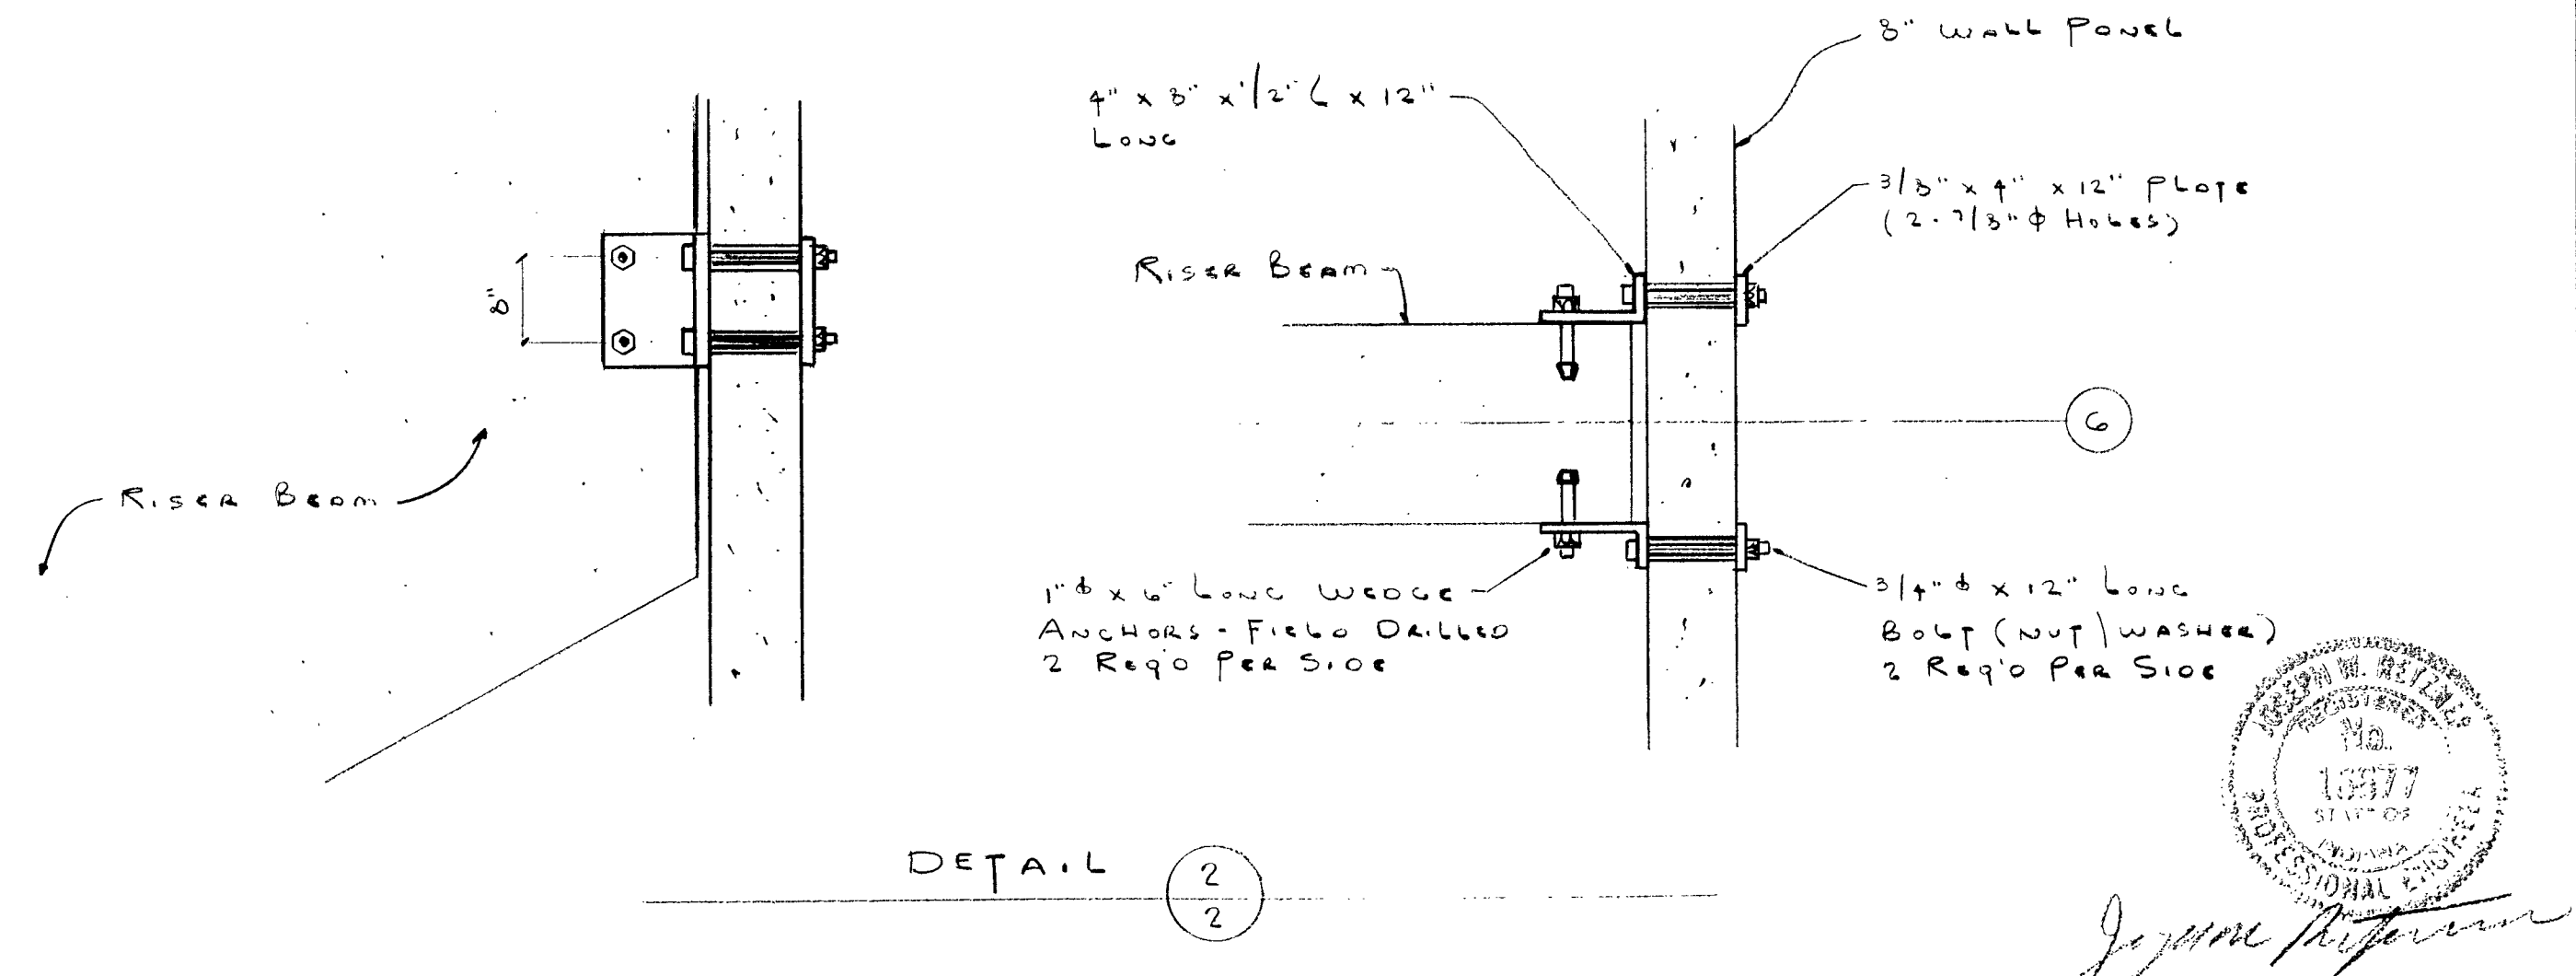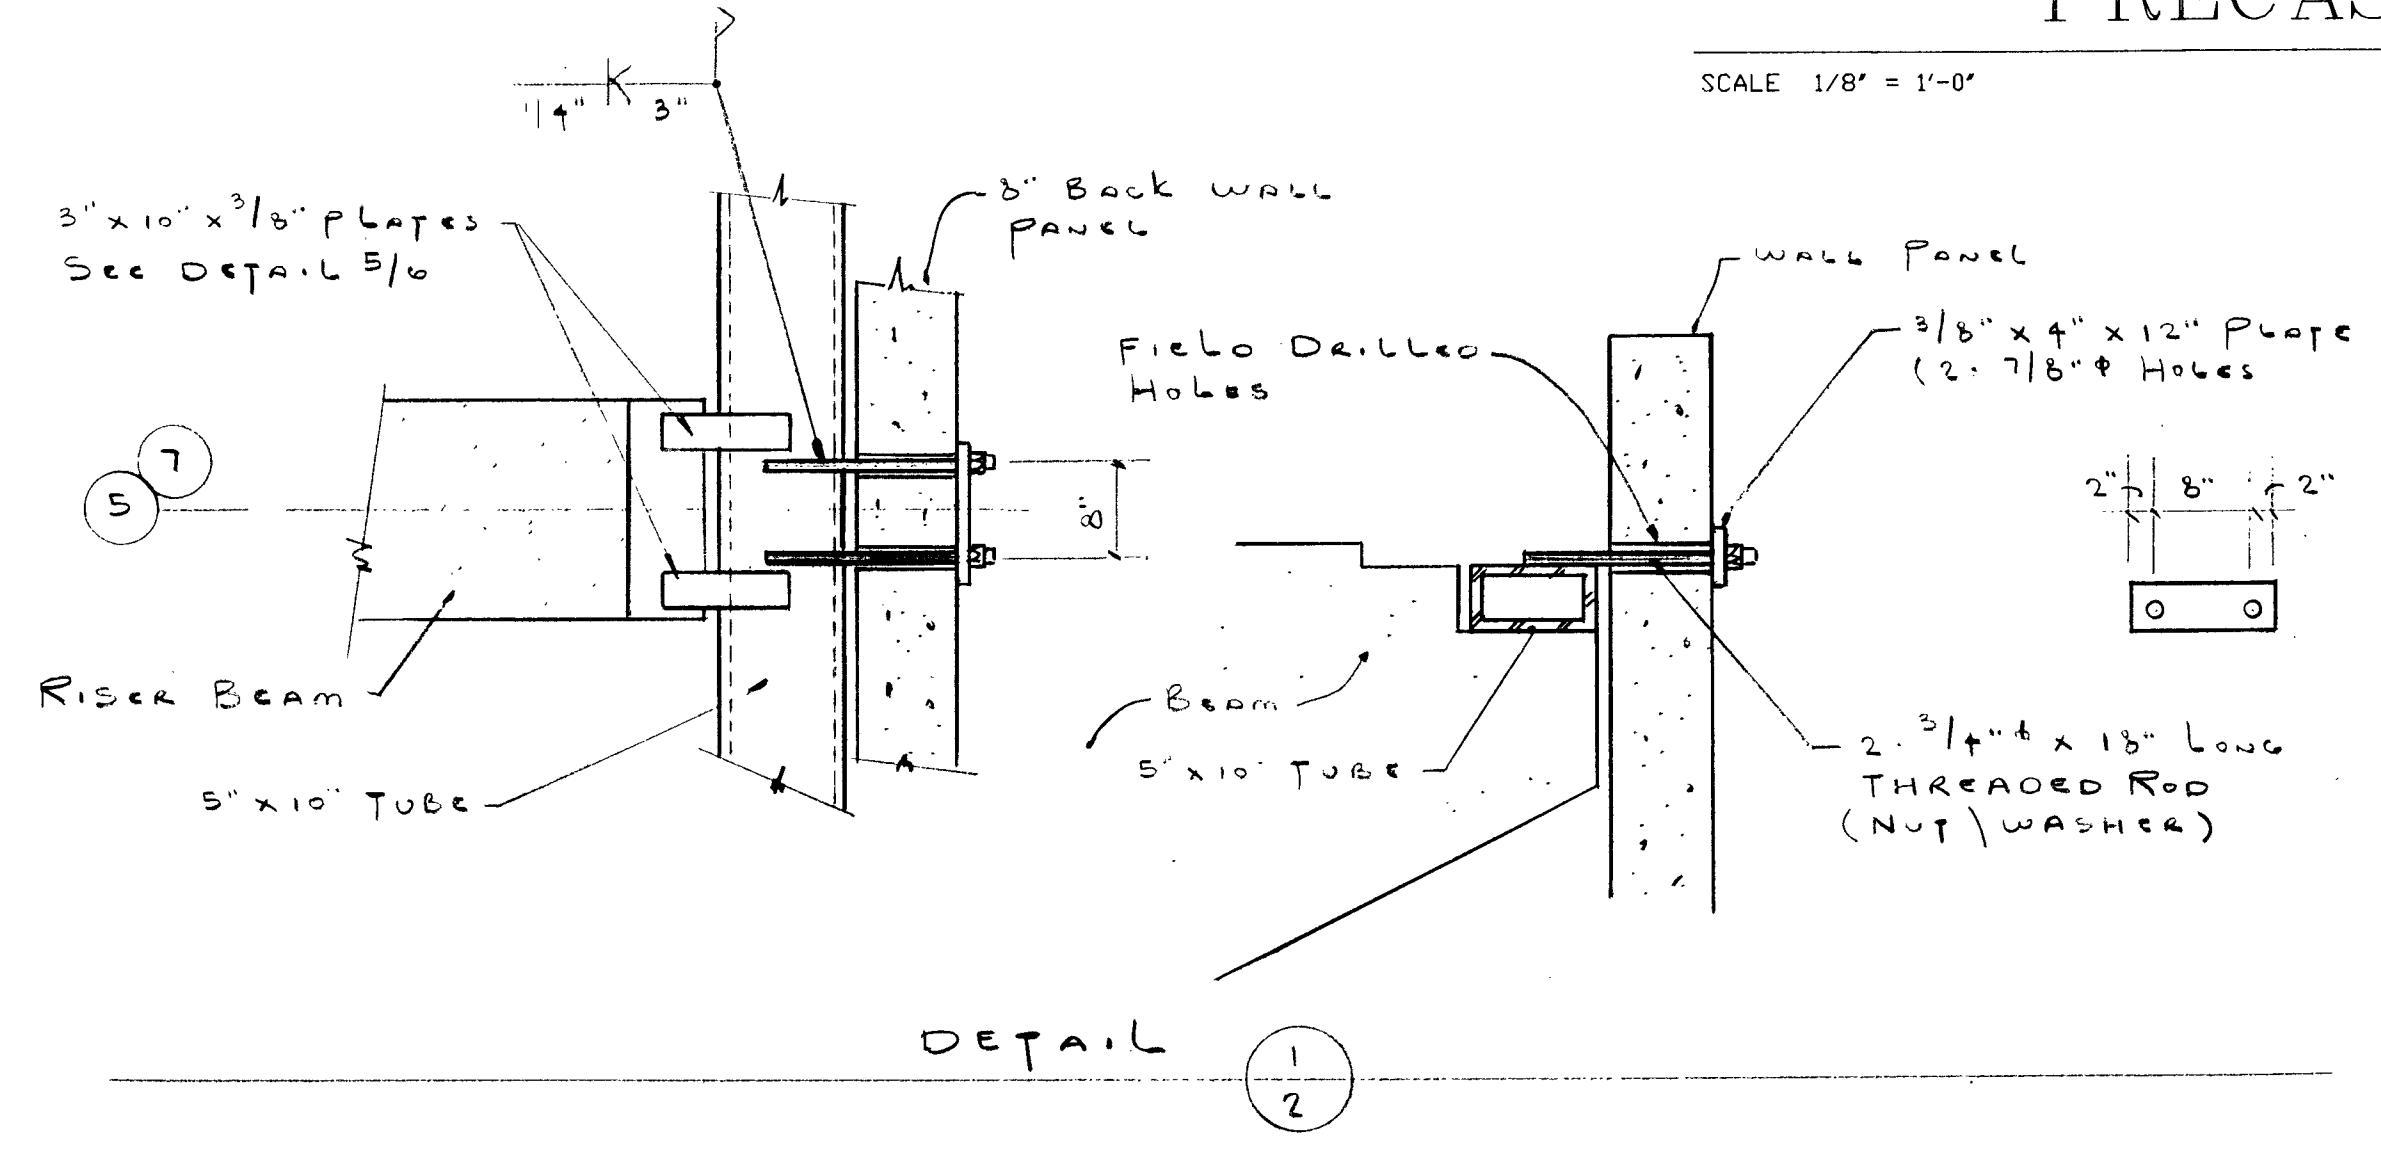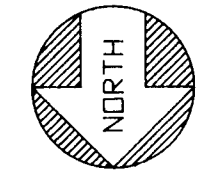

PROJECT FOR
AMERICAN PRECAST CONCRETE

PREPARED BY
PRECAST CONCRETE SYSTEMS, INC.

SUBSIDIARY OF AMERICAN PRECAST CONCRETE
1030 S. KITLEY AVE.
INDIANAPOLIS, INDIANA 46203

AMERICAN PRECAST CONCRETE

REVISIONS		REVISIONS		REVISIONS		REVISIONS	
NO.	DATE	NO.	DATE	NO.	DATE	NO.	DATE
1	8/23/14	2	9/15/14				
2	9/15/14						

ARCHITECT
THE ODLE MCGUIRE & SHOOK CORPORATION

CONTRACTOR
CONSTRUCTION CONTROL

DRAWN BY
RM

CHECK BY
JVR


DATE
7/15/14

AMES FIELD
MICHIGAN CITY, IND.

JOB NO. **1195**



SHEET **2**

OF SHEETS

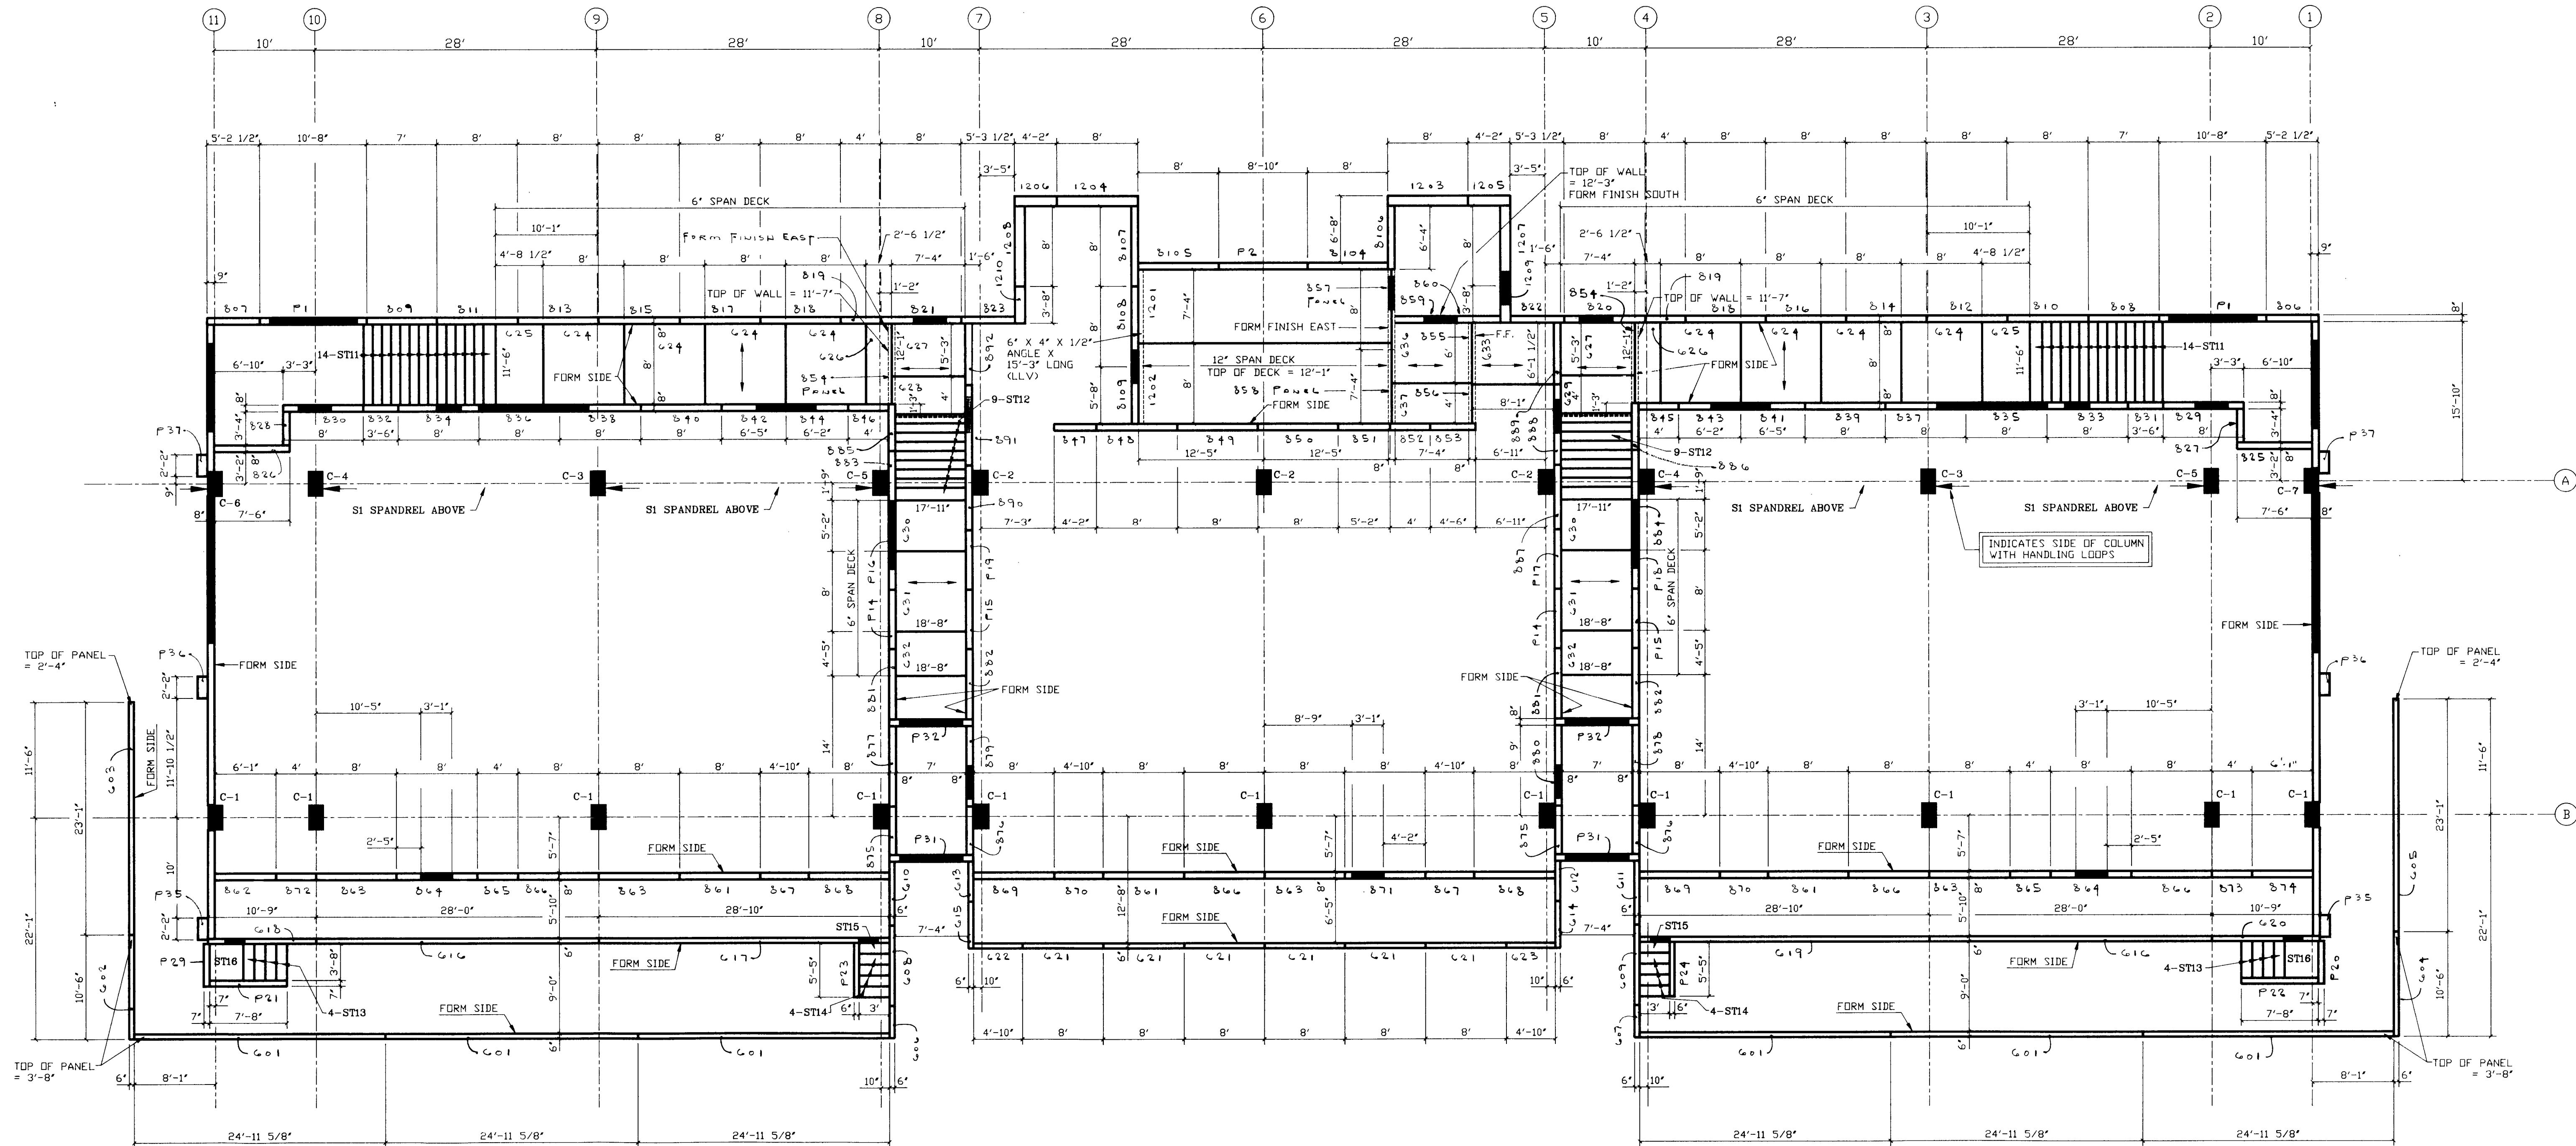


PRECAST PANEL LAYOUT


SCALE 1/8" = 1'-0"

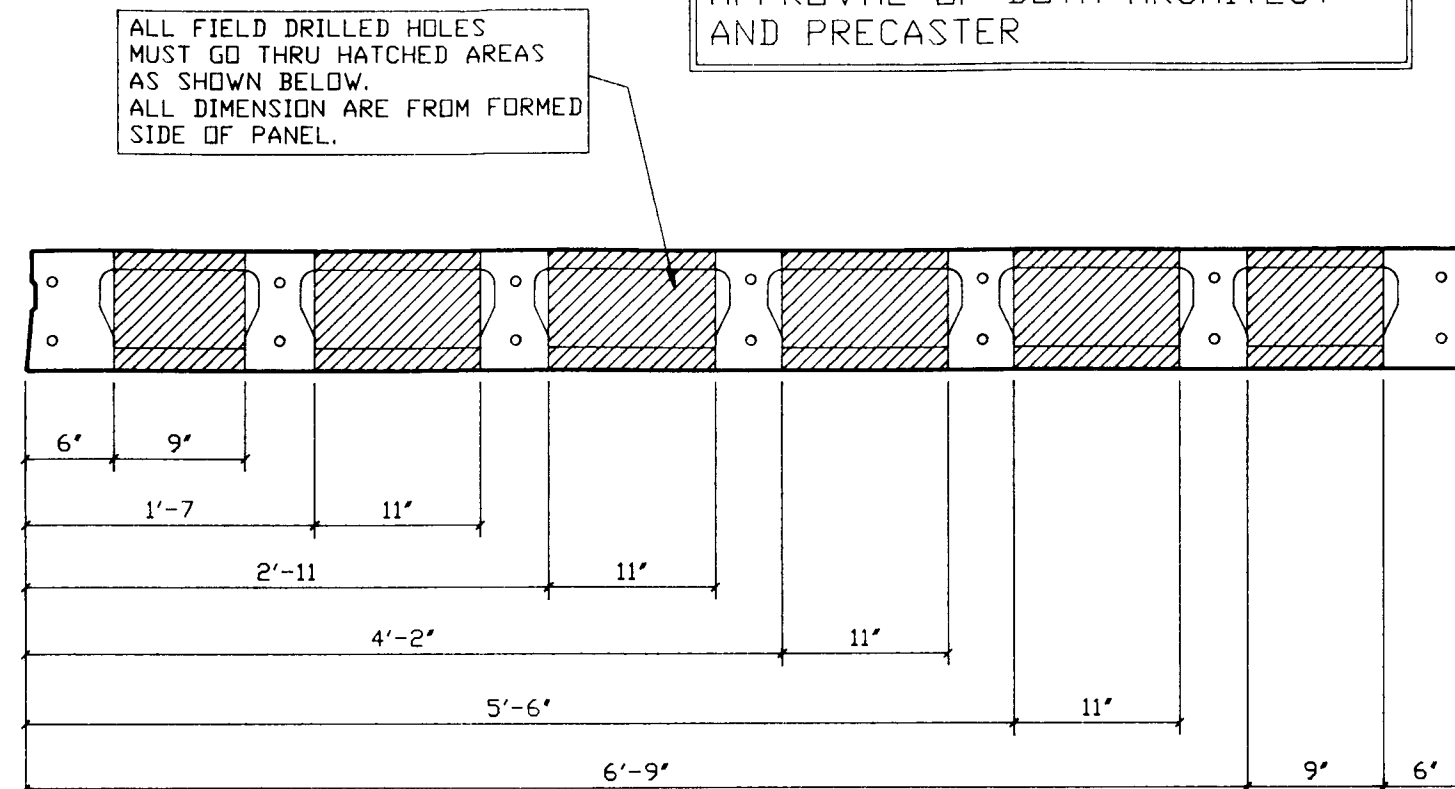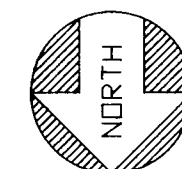

TYPICAL SPAN DECK SECTION

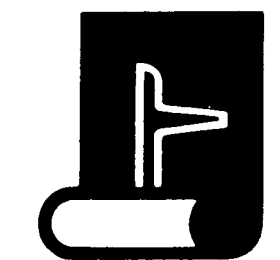

PROJECT FOR
AMERICAN PRECAST CONCRETE
 PREPARED BY
PRECAST CONCRETE SYSTEMS, INC.
 A DIVISION OF AMERICAN PRECAST CONCRETE
 1030 S. KITLEY AVE.
 INDIANAPOLIS, INDIANA 46203

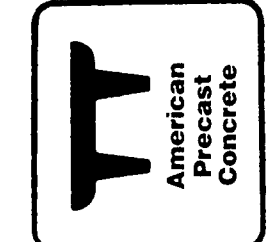

REVISIONS	NO.	DATE	BY	DESCRIPTION
1	8/13/14	RM		
2	9/10/14	RM		

REVISIONS	NO.	DATE	BY	DESCRIPTION
1	8/13/14	RM		
2	9/10/14	RM		

REVISIONS	NO.	DATE	BY	DESCRIPTION
1	8/13/14	RM		
2	9/10/14	RM		

ARCHITECT	EDLE ACQUIRE & SHOOK CORPORATION
CONTRACTOR	CONSTRUCTION CONTROL
DRAWN BY	RM
CHECK BY	JWR
DATE	8/14/14

AMES FIELD
 MICHIGAN CITY, IND.


JOB NO. 1195

SHEET


2A

OF SHEETS

Signature

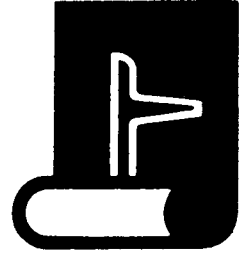

PROJECT FOR
AMERICAN PRECAST CONCRETE
PREPARED BY
PRECAST CONCRETE SYSTEMS, INC.
SUBSIDIARY OF AMERICAN PRECAST CONCRETE
1030 S. KITLEY AVE.
INDIANAPOLIS, INDIANA 46203

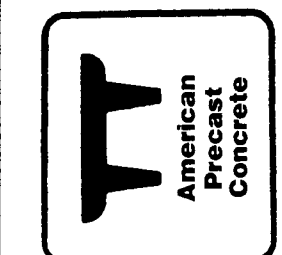


REVISIONS		REVISIONS		REVISIONS		REVISIONS	
NO.	DATE	NO.	DATE	NO.	DATE	NO.	DATE
1	8/13/84	2	8/13/84	3	8/13/84	4	8/13/84
5	8/13/84	6	8/13/84	7	8/13/84	8	8/13/84
9	8/13/84	10	8/13/84	11	8/13/84	12	8/13/84
13	8/13/84	14	8/13/84	15	8/13/84	16	8/13/84
17	8/13/84	18	8/13/84	19	8/13/84	20	8/13/84
21	8/13/84	22	8/13/84	23	8/13/84	24	8/13/84
25	8/13/84	26	8/13/84	27	8/13/84	28	8/13/84
29	8/13/84	30	8/13/84	31	8/13/84	32	8/13/84
33	8/13/84	34	8/13/84	35	8/13/84	36	8/13/84
37	8/13/84	38	8/13/84	39	8/13/84	40	8/13/84
41	8/13/84	42	8/13/84	43	8/13/84	44	8/13/84
45	8/13/84	46	8/13/84	47	8/13/84	48	8/13/84
49	8/13/84	50	8/13/84	51	8/13/84	52	8/13/84
53	8/13/84	54	8/13/84	55	8/13/84	56	8/13/84
57	8/13/84	58	8/13/84	59	8/13/84	60	8/13/84
61	8/13/84	62	8/13/84	63	8/13/84	64	8/13/84
65	8/13/84	66	8/13/84	67	8/13/84	68	8/13/84
69	8/13/84	70	8/13/84	71	8/13/84	72	8/13/84
73	8/13/84	74	8/13/84	75	8/13/84	76	8/13/84
77	8/13/84	78	8/13/84	79	8/13/84	80	8/13/84
81	8/13/84	82	8/13/84	83	8/13/84	84	8/13/84
85	8/13/84	86	8/13/84	87	8/13/84	88	8/13/84
89	8/13/84	90	8/13/84	91	8/13/84	92	8/13/84
93	8/13/84	94	8/13/84	95	8/13/84	96	8/13/84
97	8/13/84	98	8/13/84	99	8/13/84	100	8/13/84

ARCHITECT
THE OBLE MCQUIRE &
SHOOK CORPORATION
CONTRACTOR
CONSTRUCTION CONTROL
DRAWN BY
JWR
DATE
7/11/84







AMES FIELD
MICHIGAN CITY, IND.

JOB NO. 1195
SHEET 3
OF SHEETS

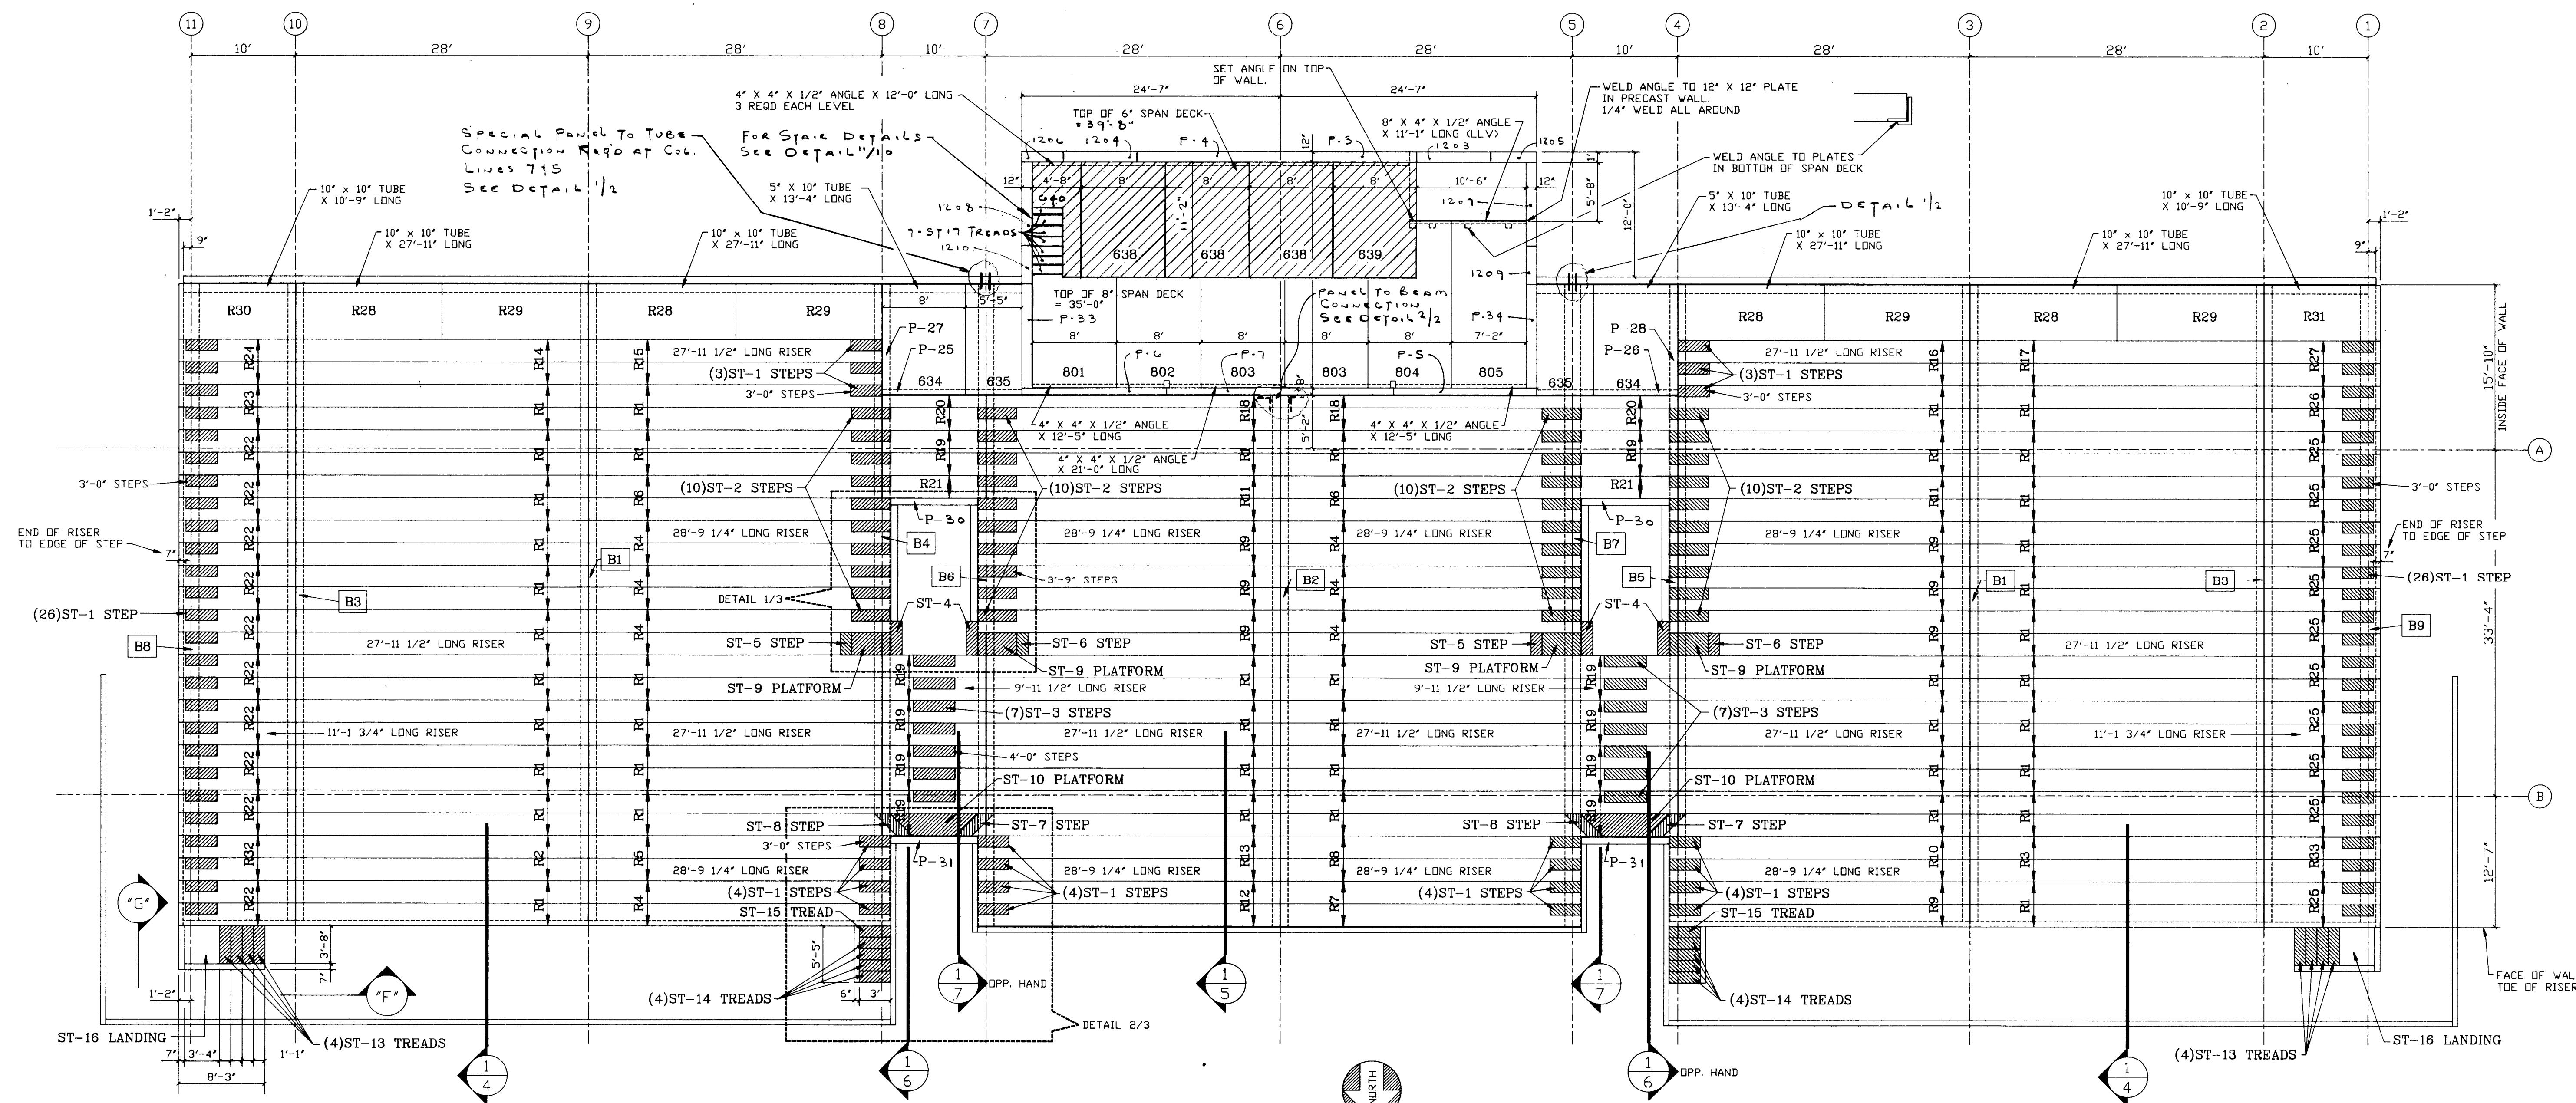


PRECAST PLAN

SCALE 1/8" = 1'-0"

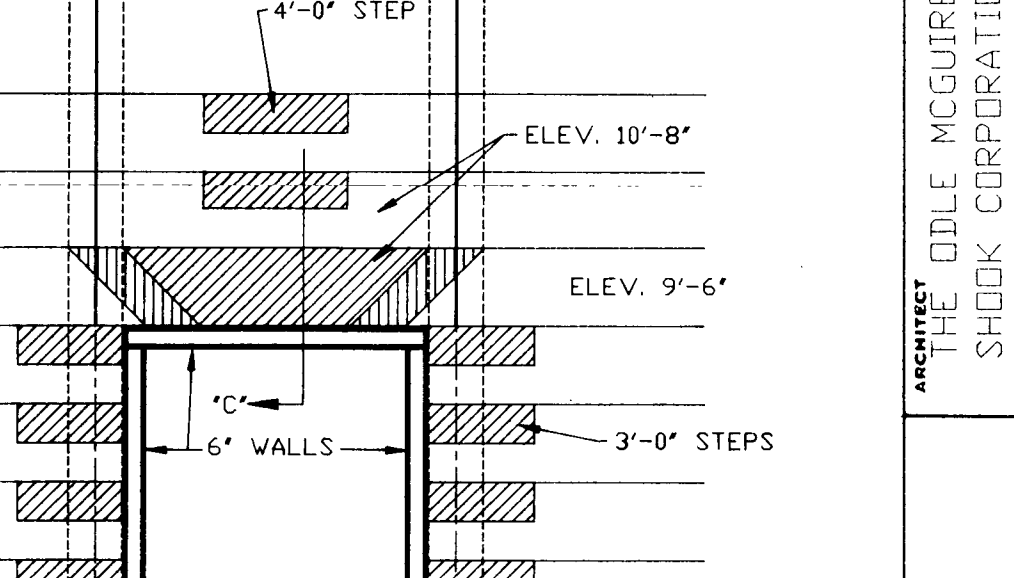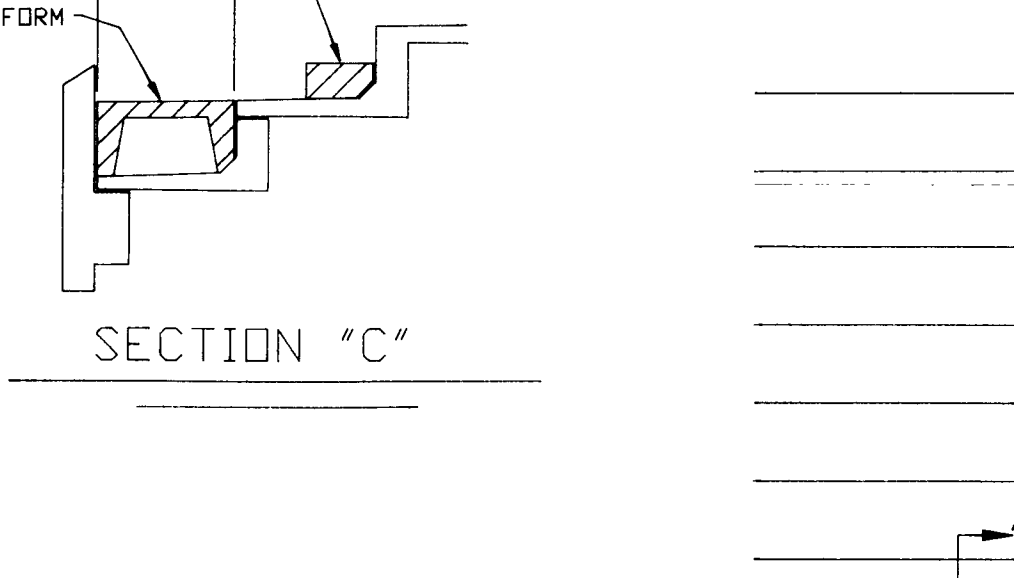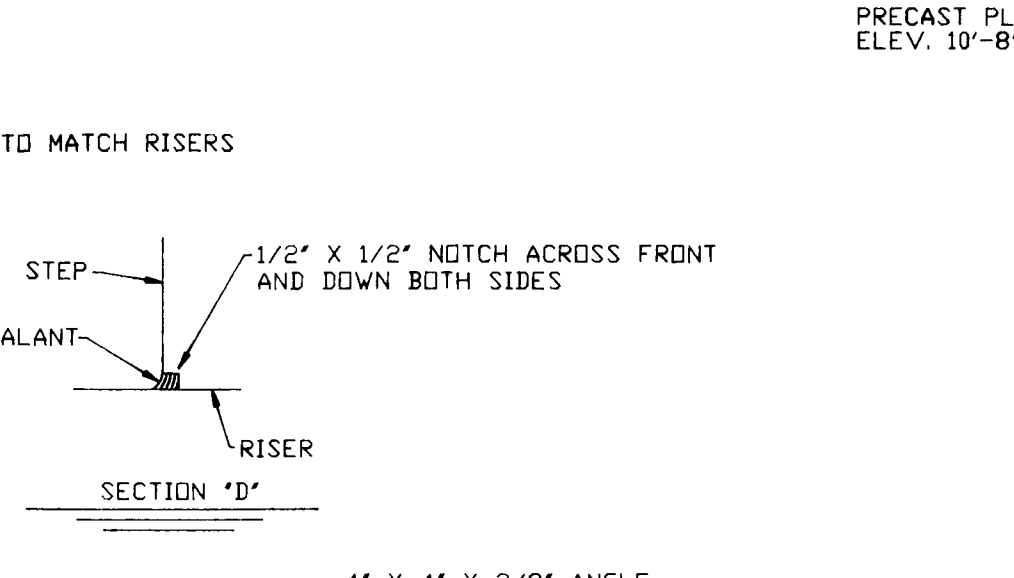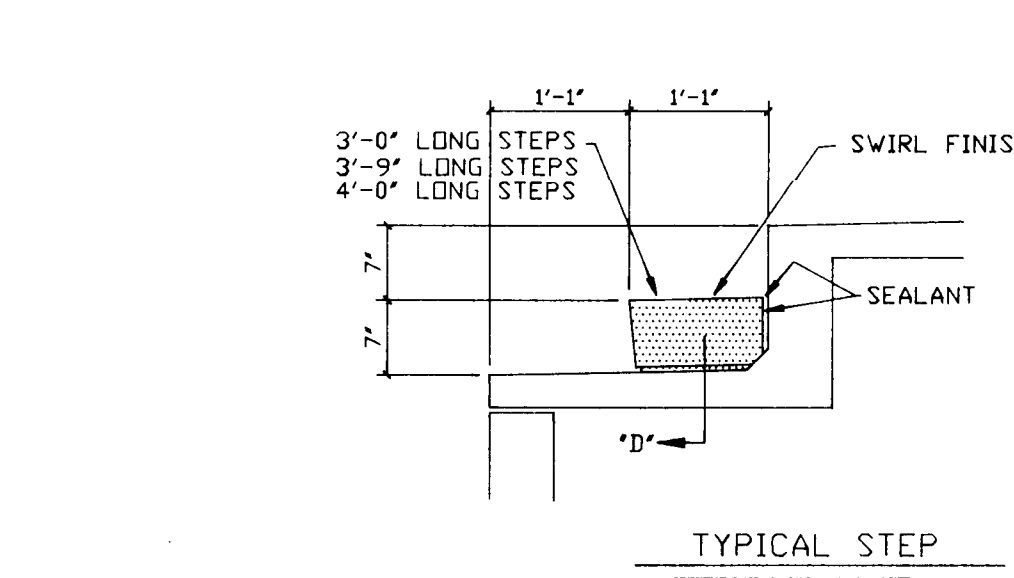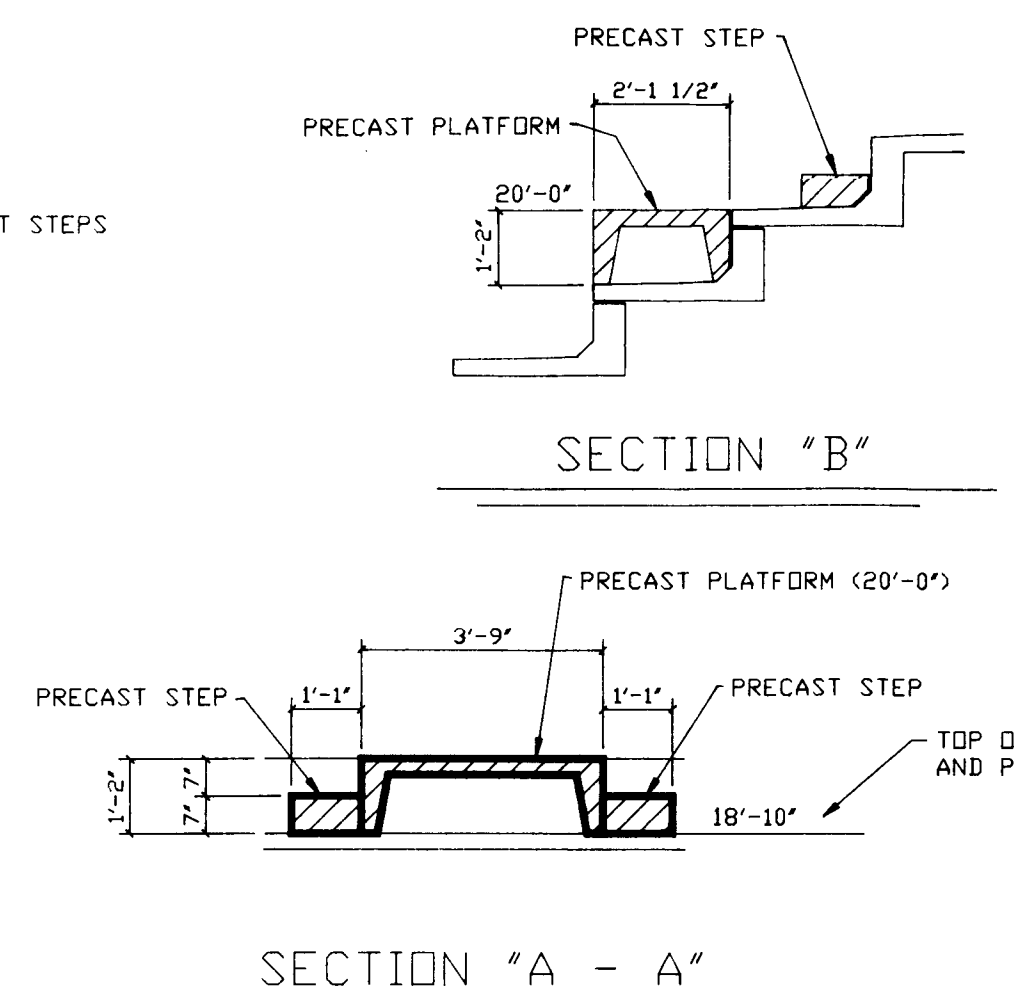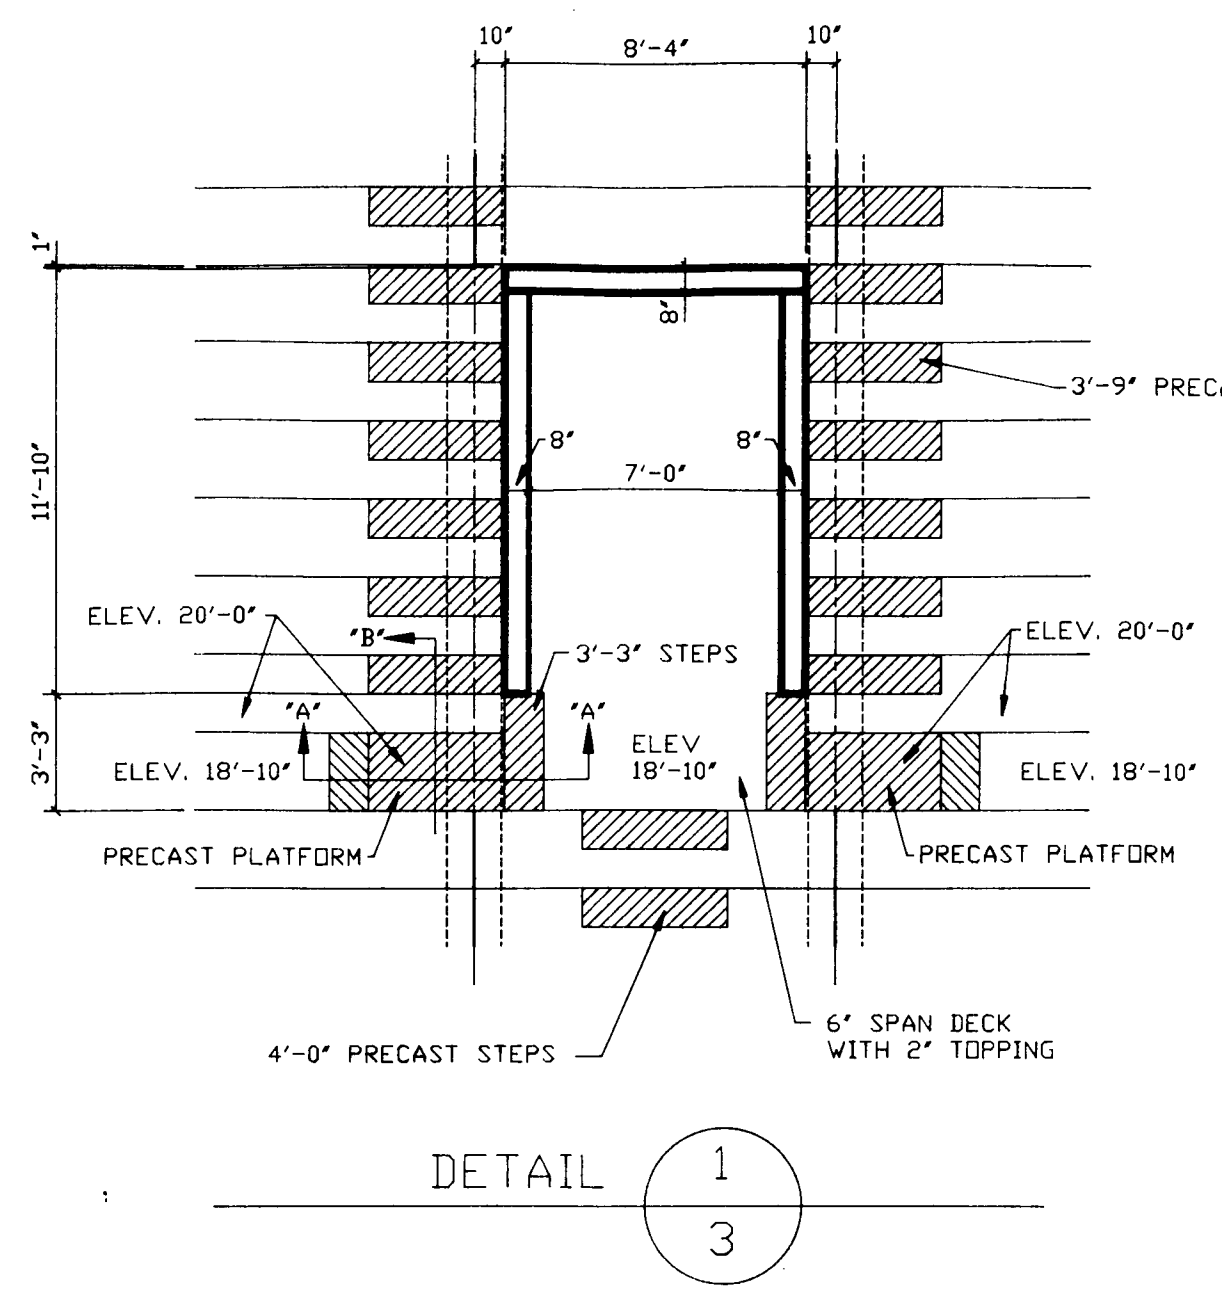

SECTION 1
SCALE 3/8" = 1'-0"

DVAMES-6
PLOT 3/8"

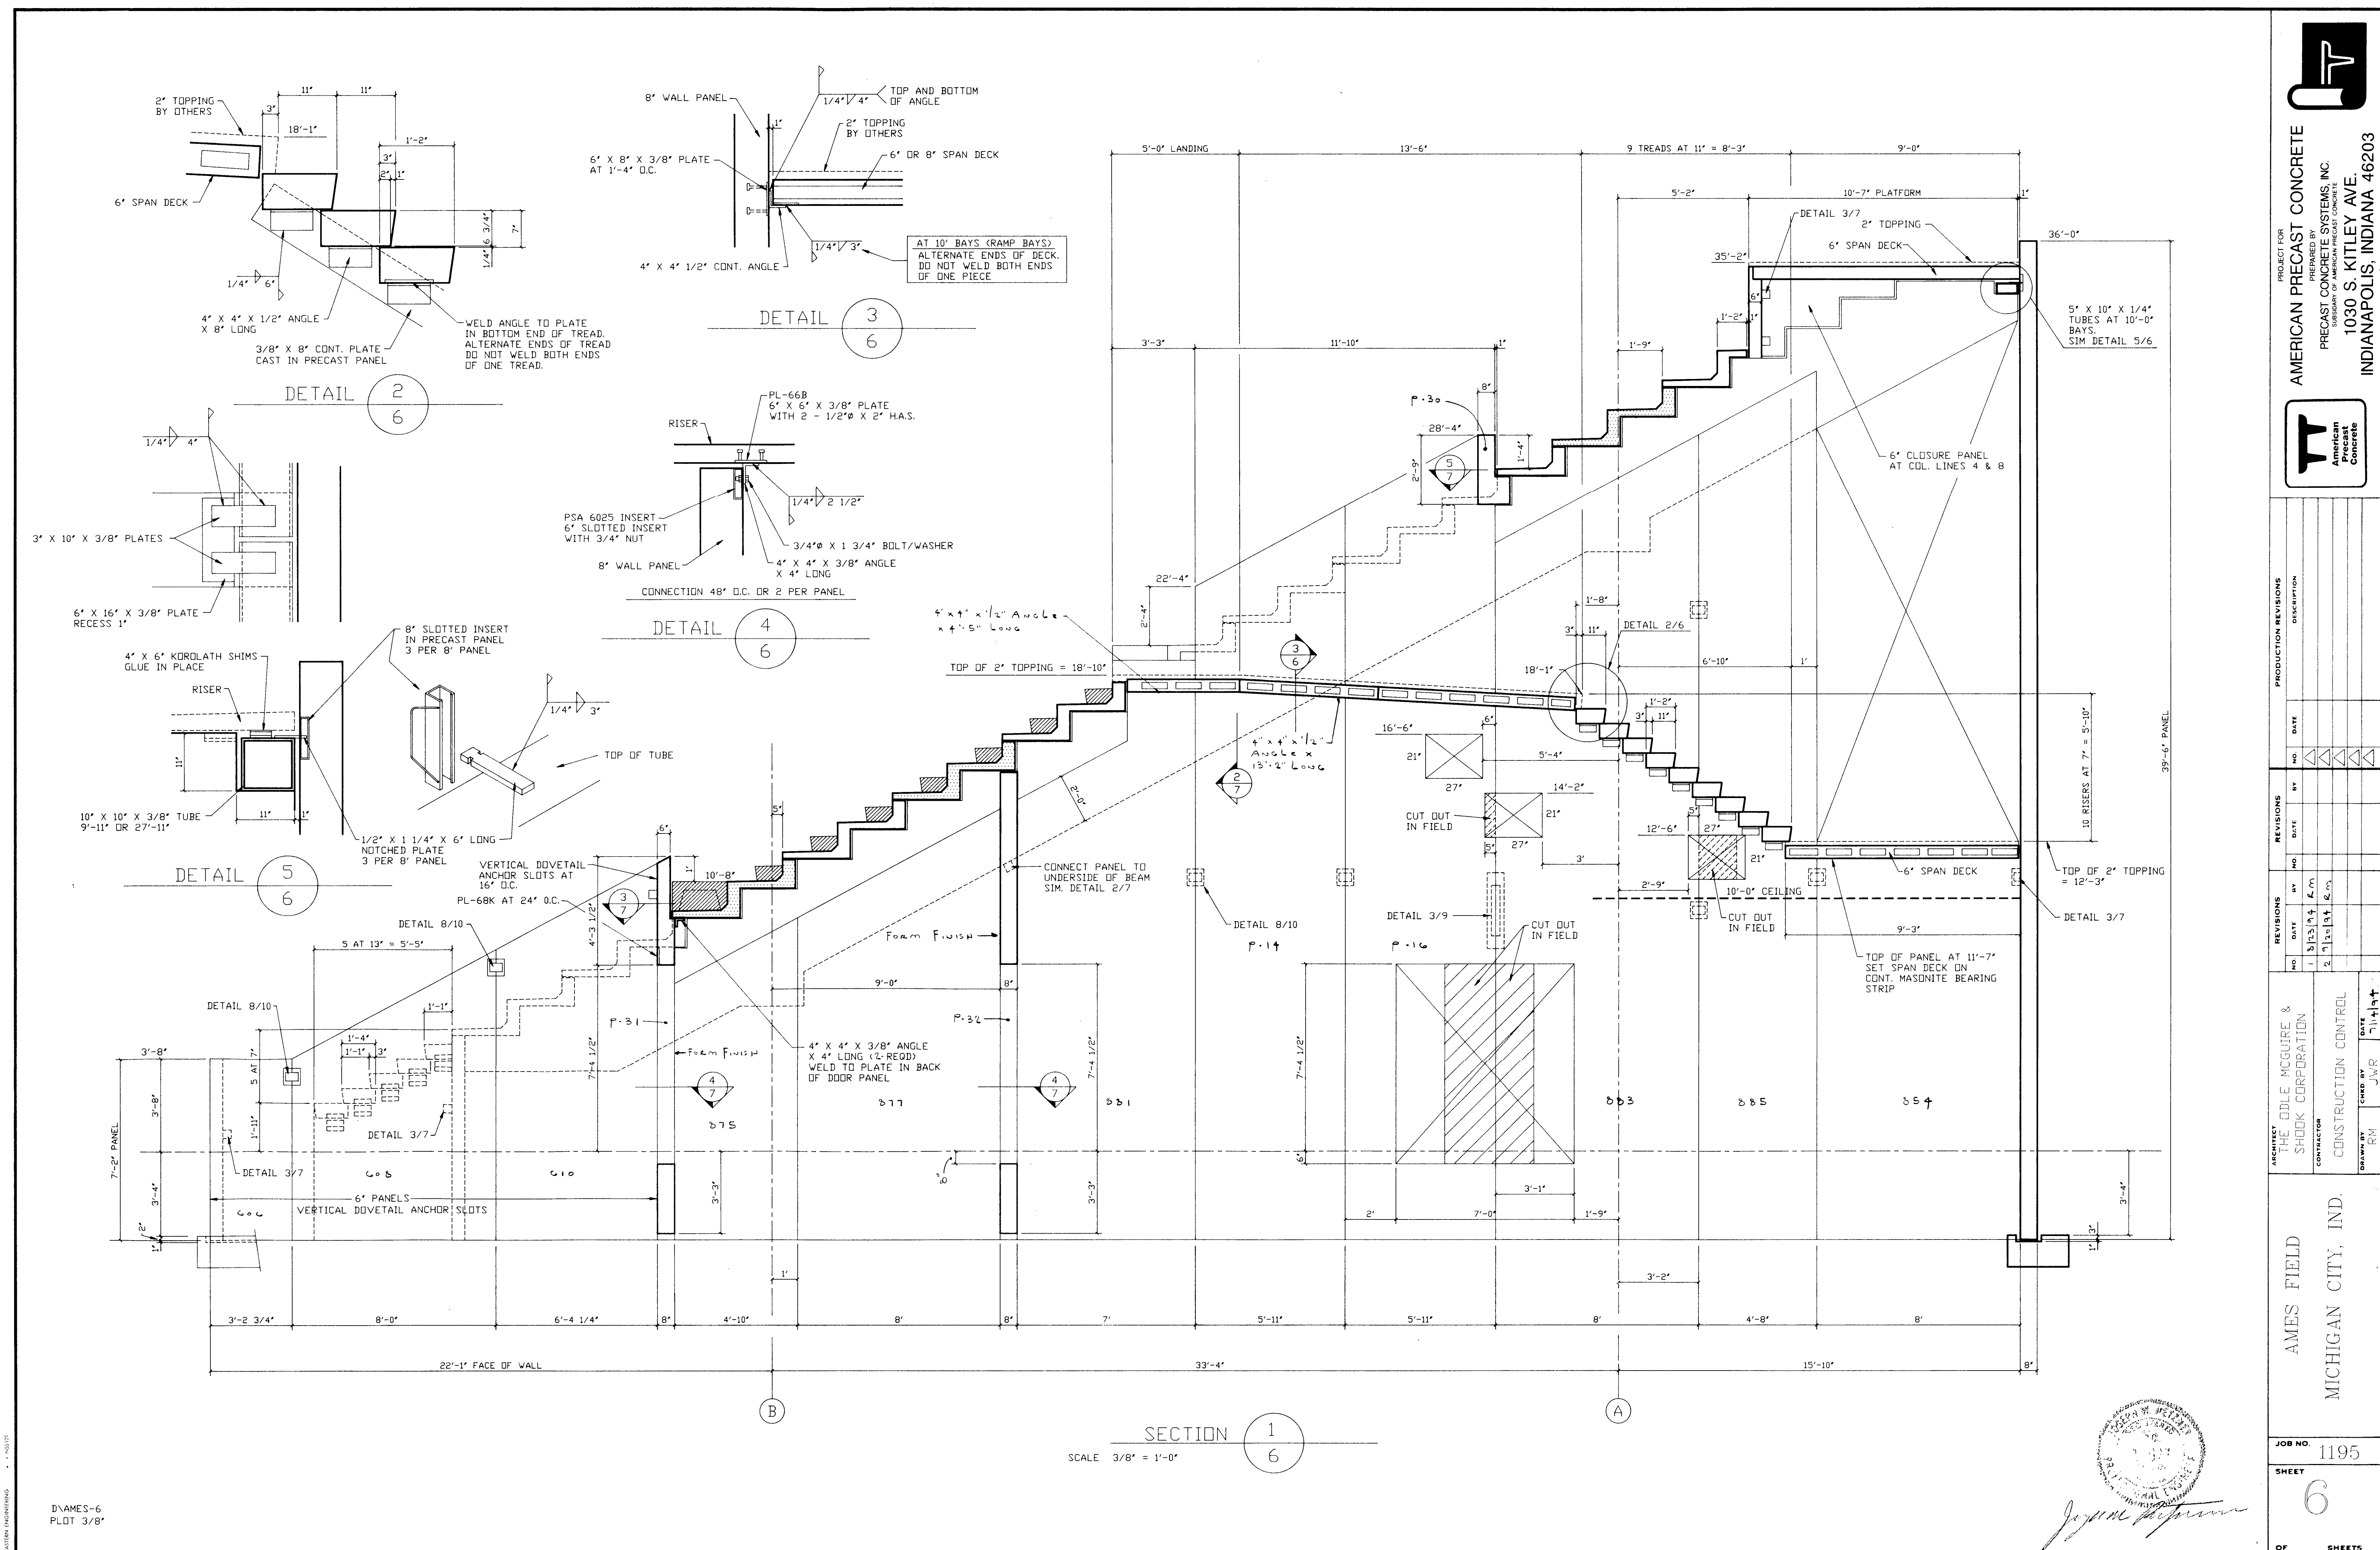

PROJECT FOR
AMERICAN PRECAST CONCRETE
PREPARED BY
PRECAST CONCRETE SYSTEMS, INC.
SUBSIDIARY OF AMERICAN PRECAST CONCRETE
1030 S. KITLEY AVE.
INDIANAPOLIS, INDIANA 46203

PRODUCTION REVISIONS

NO.	DATE	DESCRIPTION
1	7/1/94	1
2	7/1/94	2
3	7/1/94	3
4	7/1/94	4
5	7/1/94	5
6	7/1/94	6
7	7/1/94	7
8	7/1/94	8
9	7/1/94	9
10	7/1/94	10

REVISIONS

NO.	DATE	BY	DESCRIPTION
1	7/1/94	LM	1
2	7/1/94	LM	2
3	7/1/94	LM	3
4	7/1/94	LM	4
5	7/1/94	LM	5
6	7/1/94	LM	6
7	7/1/94	LM	7
8	7/1/94	LM	8
9	7/1/94	LM	9
10	7/1/94	LM	10

ARCHITECT
THE ODLE MCGUIRE & SHOOK CORPORATION

CONTRACTOR
CONSTRUCTION CONTROL

DRAWN BY
RM

CHECKED BY
JVR


DATE
7/1/94

AMES FIELD
MICHIGAN CITY, IND.

JOB NO.
1195


SHEET
6

OF
SHEETS

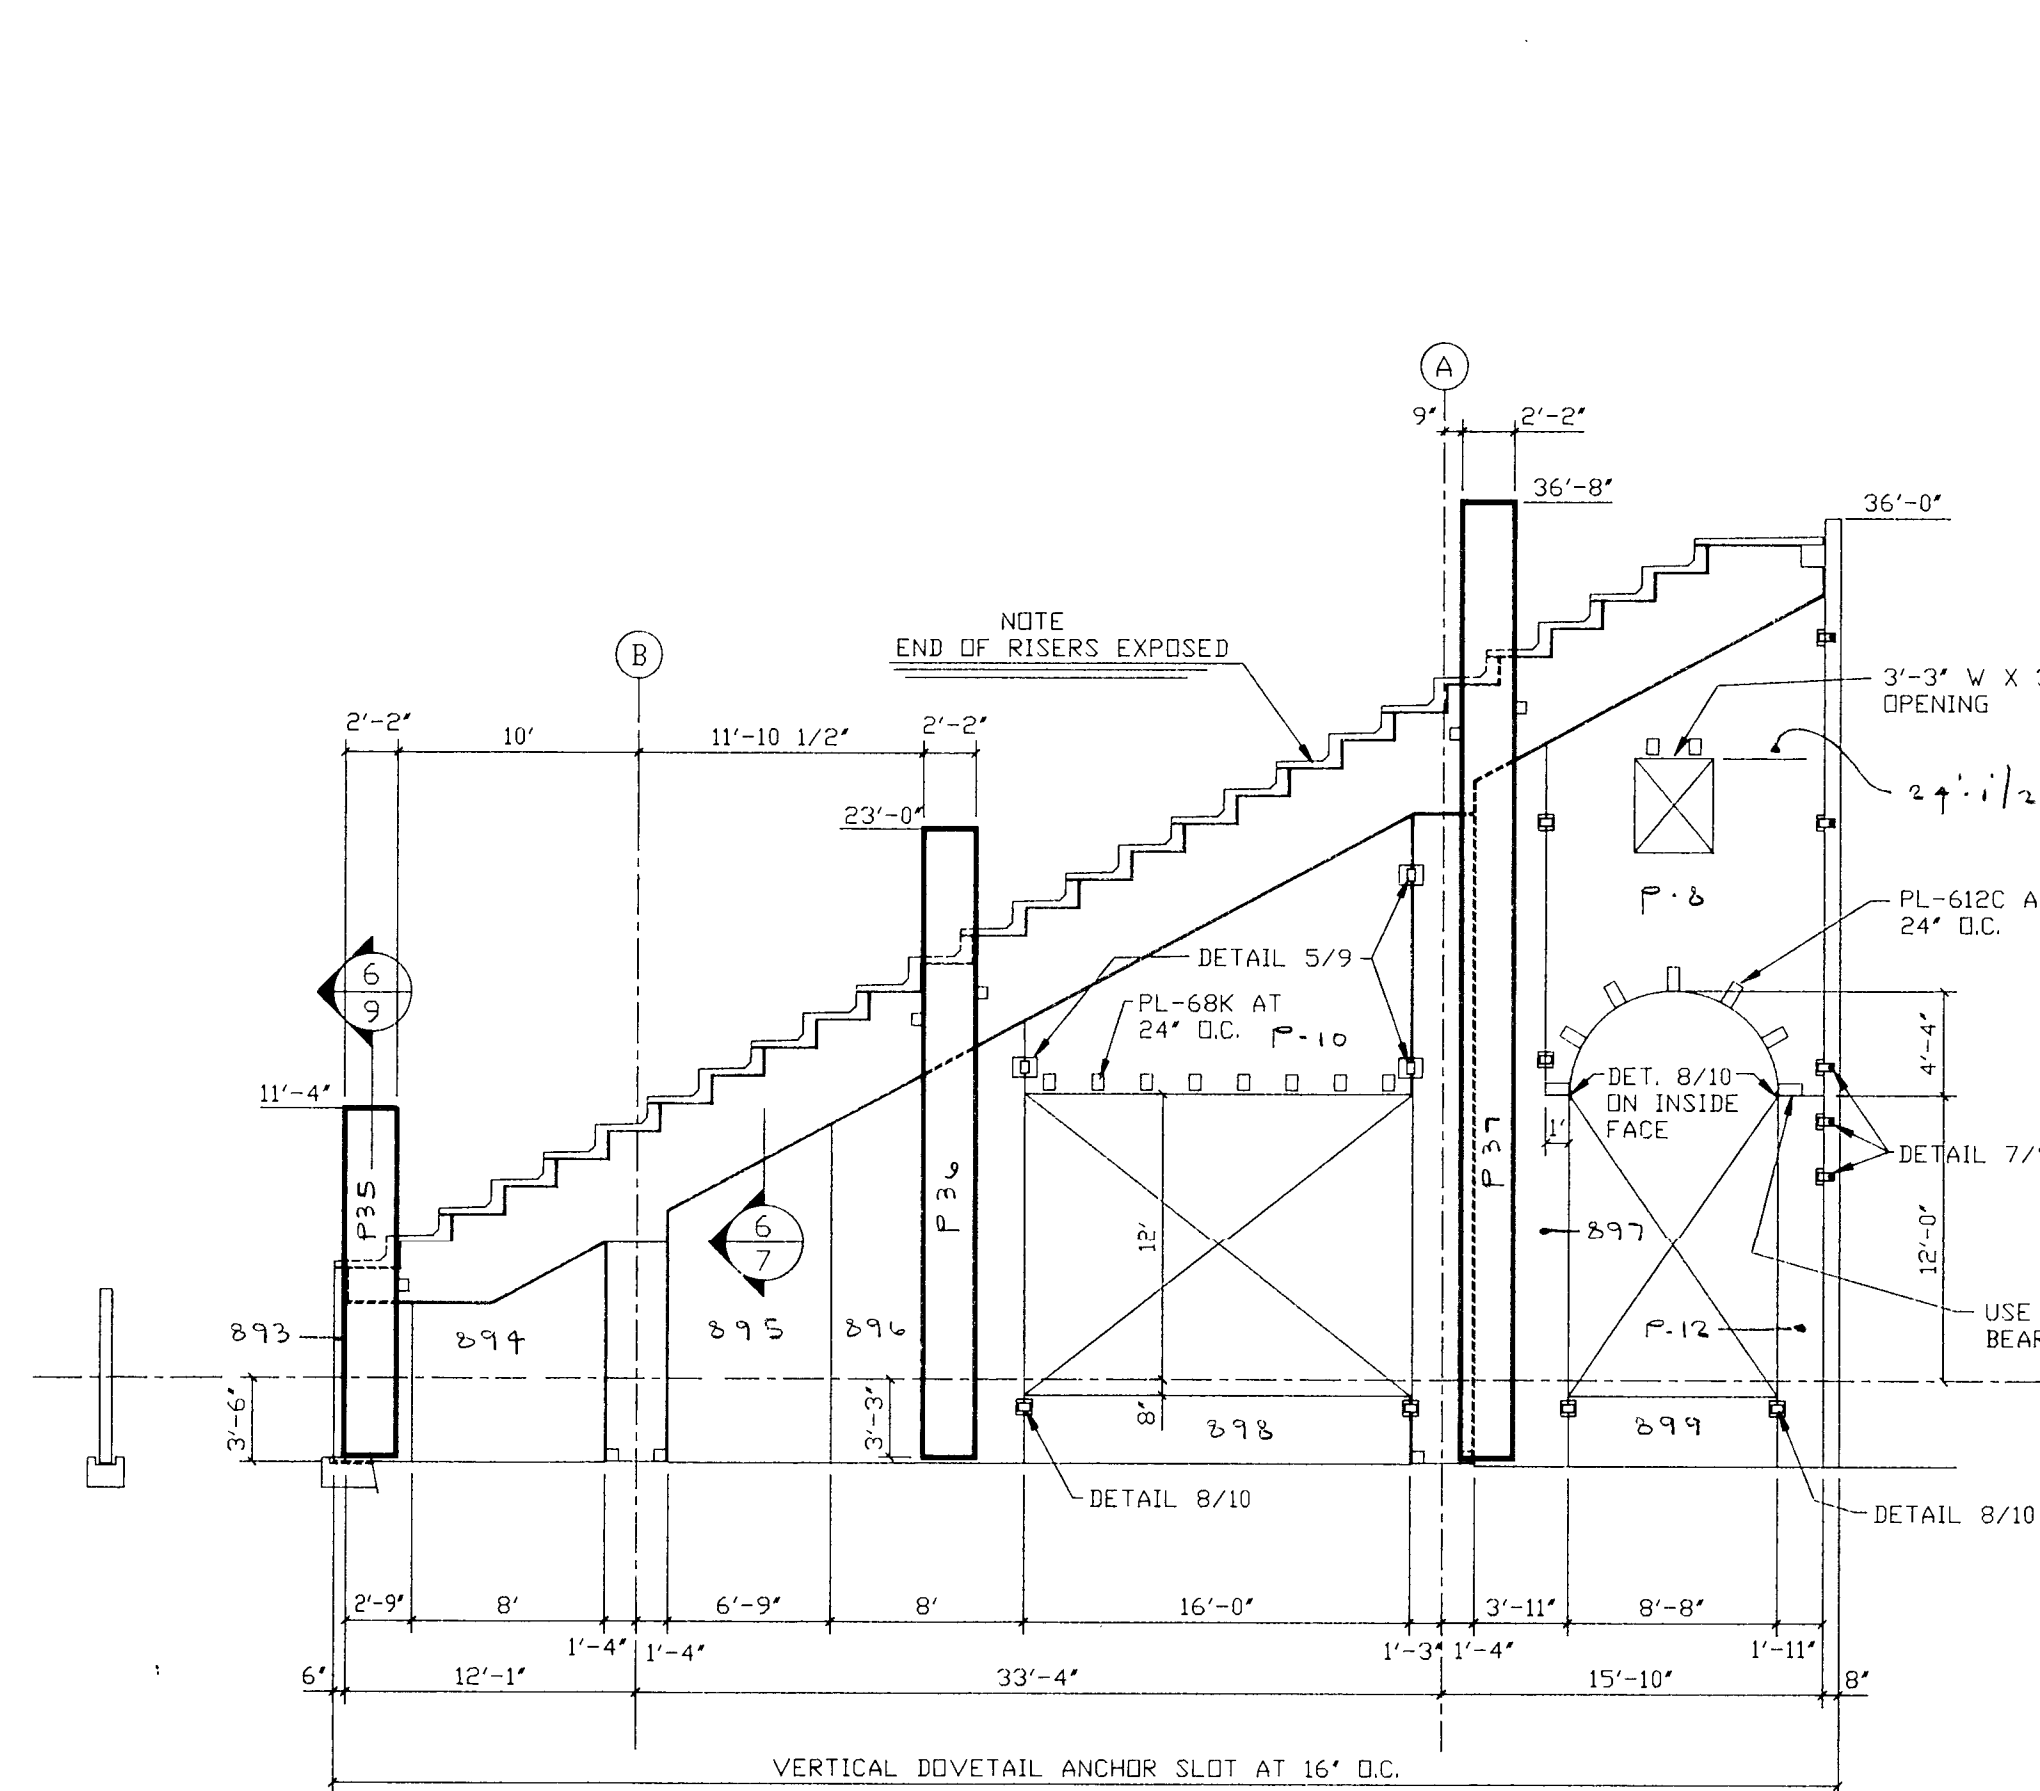


ELEVATION WEST END OF STADIUM

SCALE 1/8" = 1'-0"

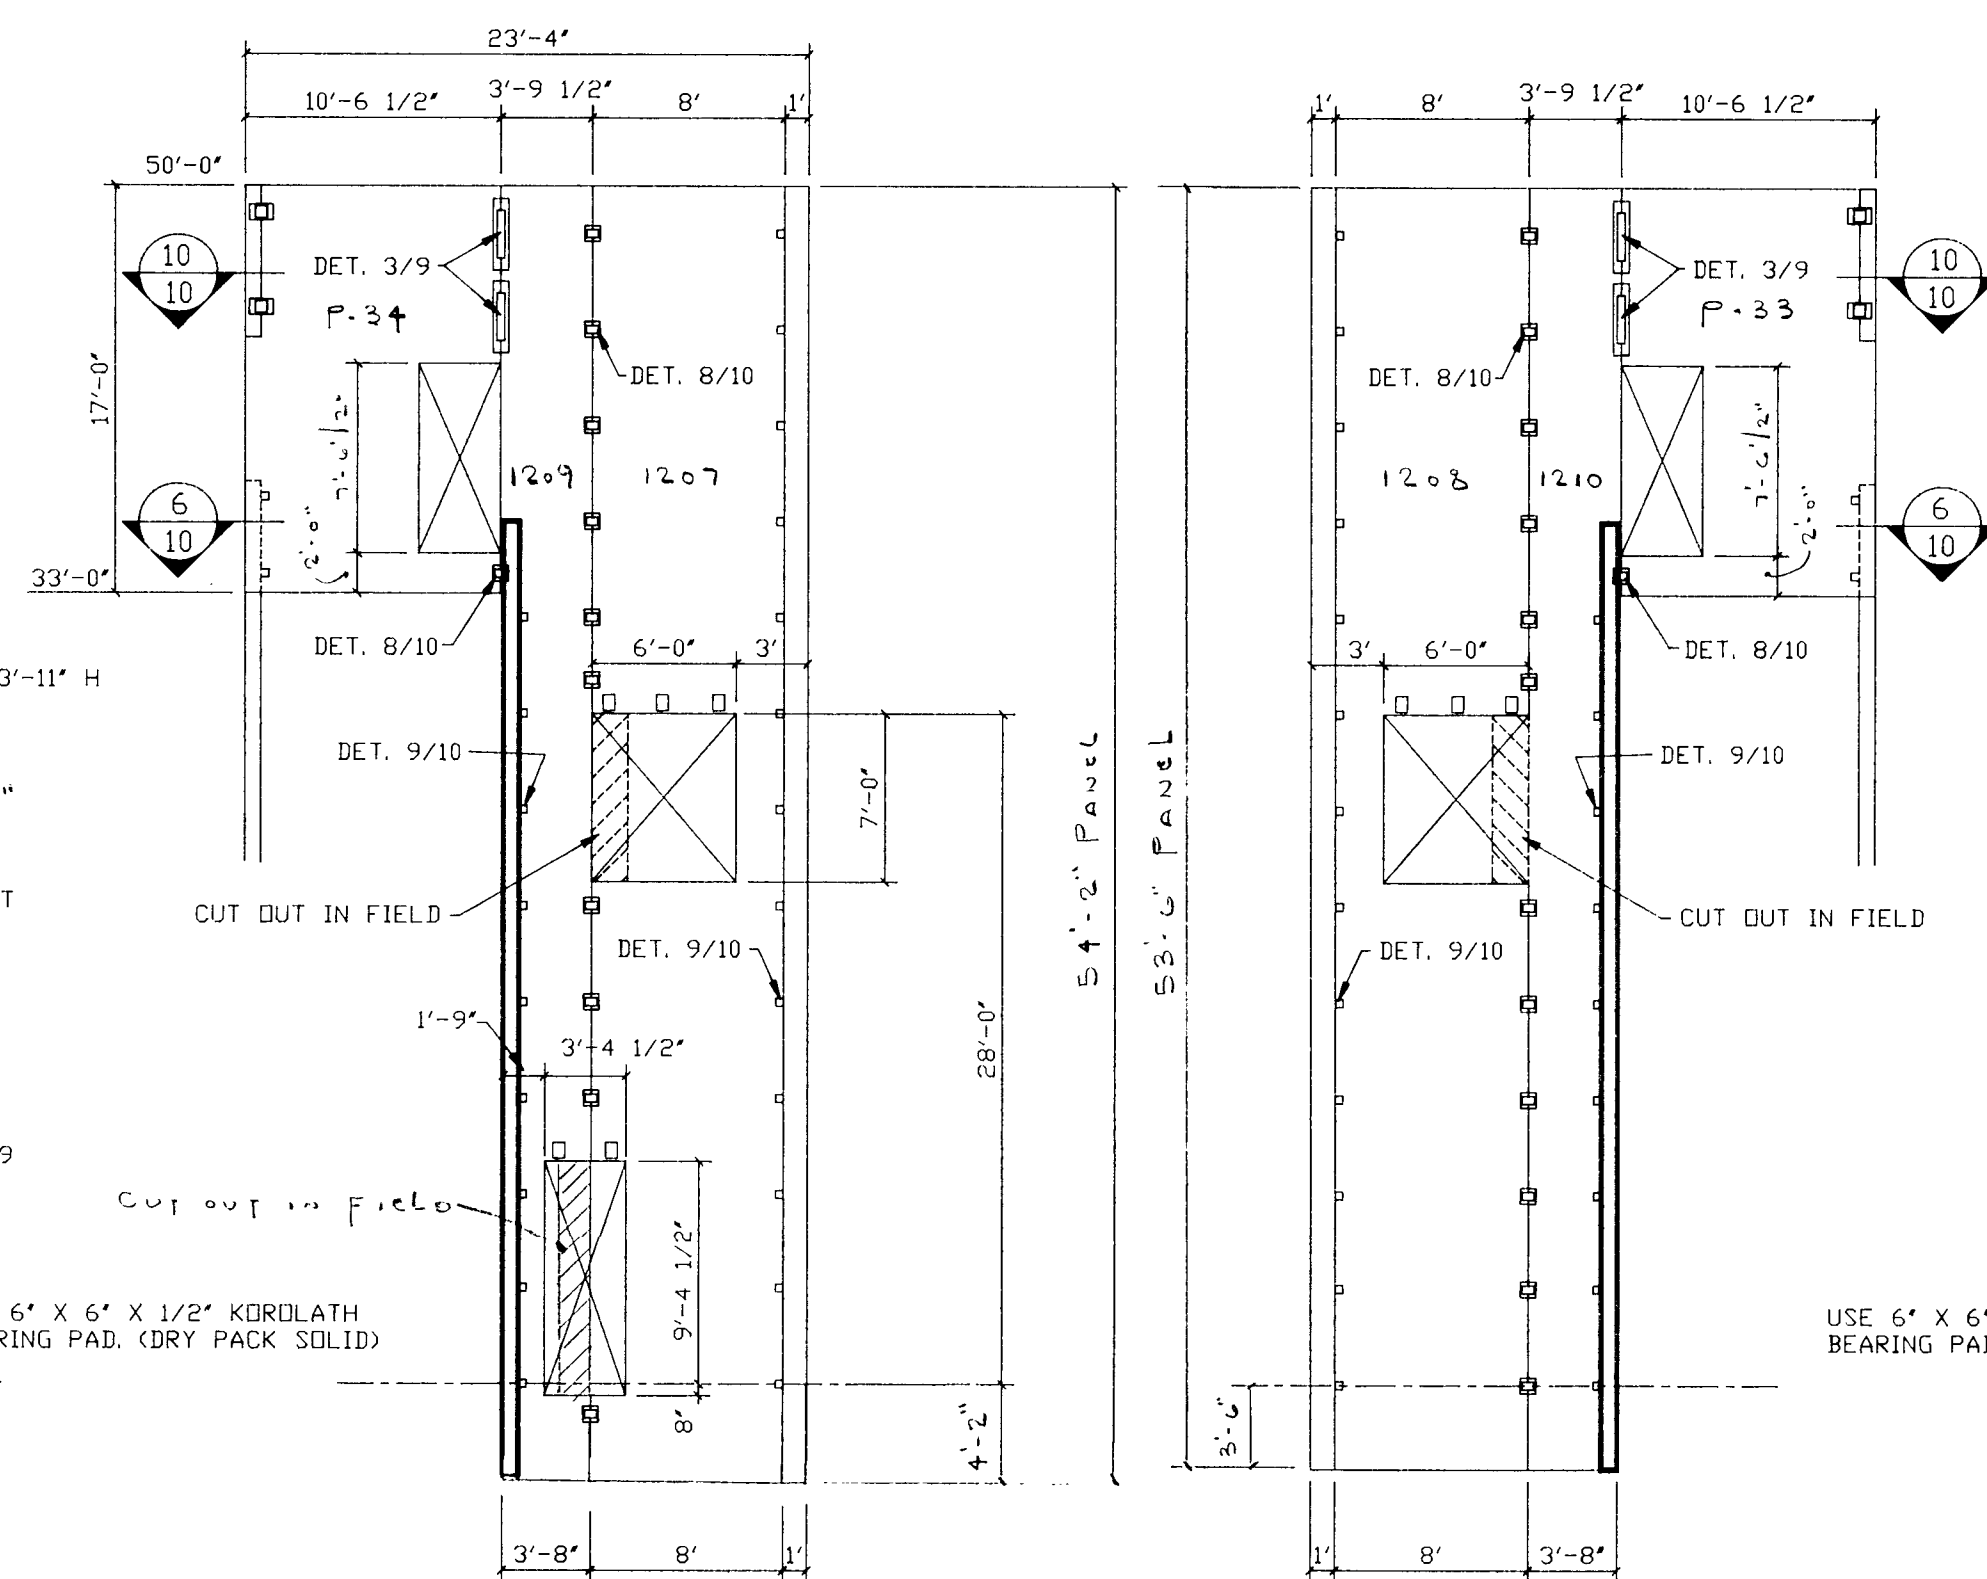


ELEVATION "A"

ELEVATION "B"

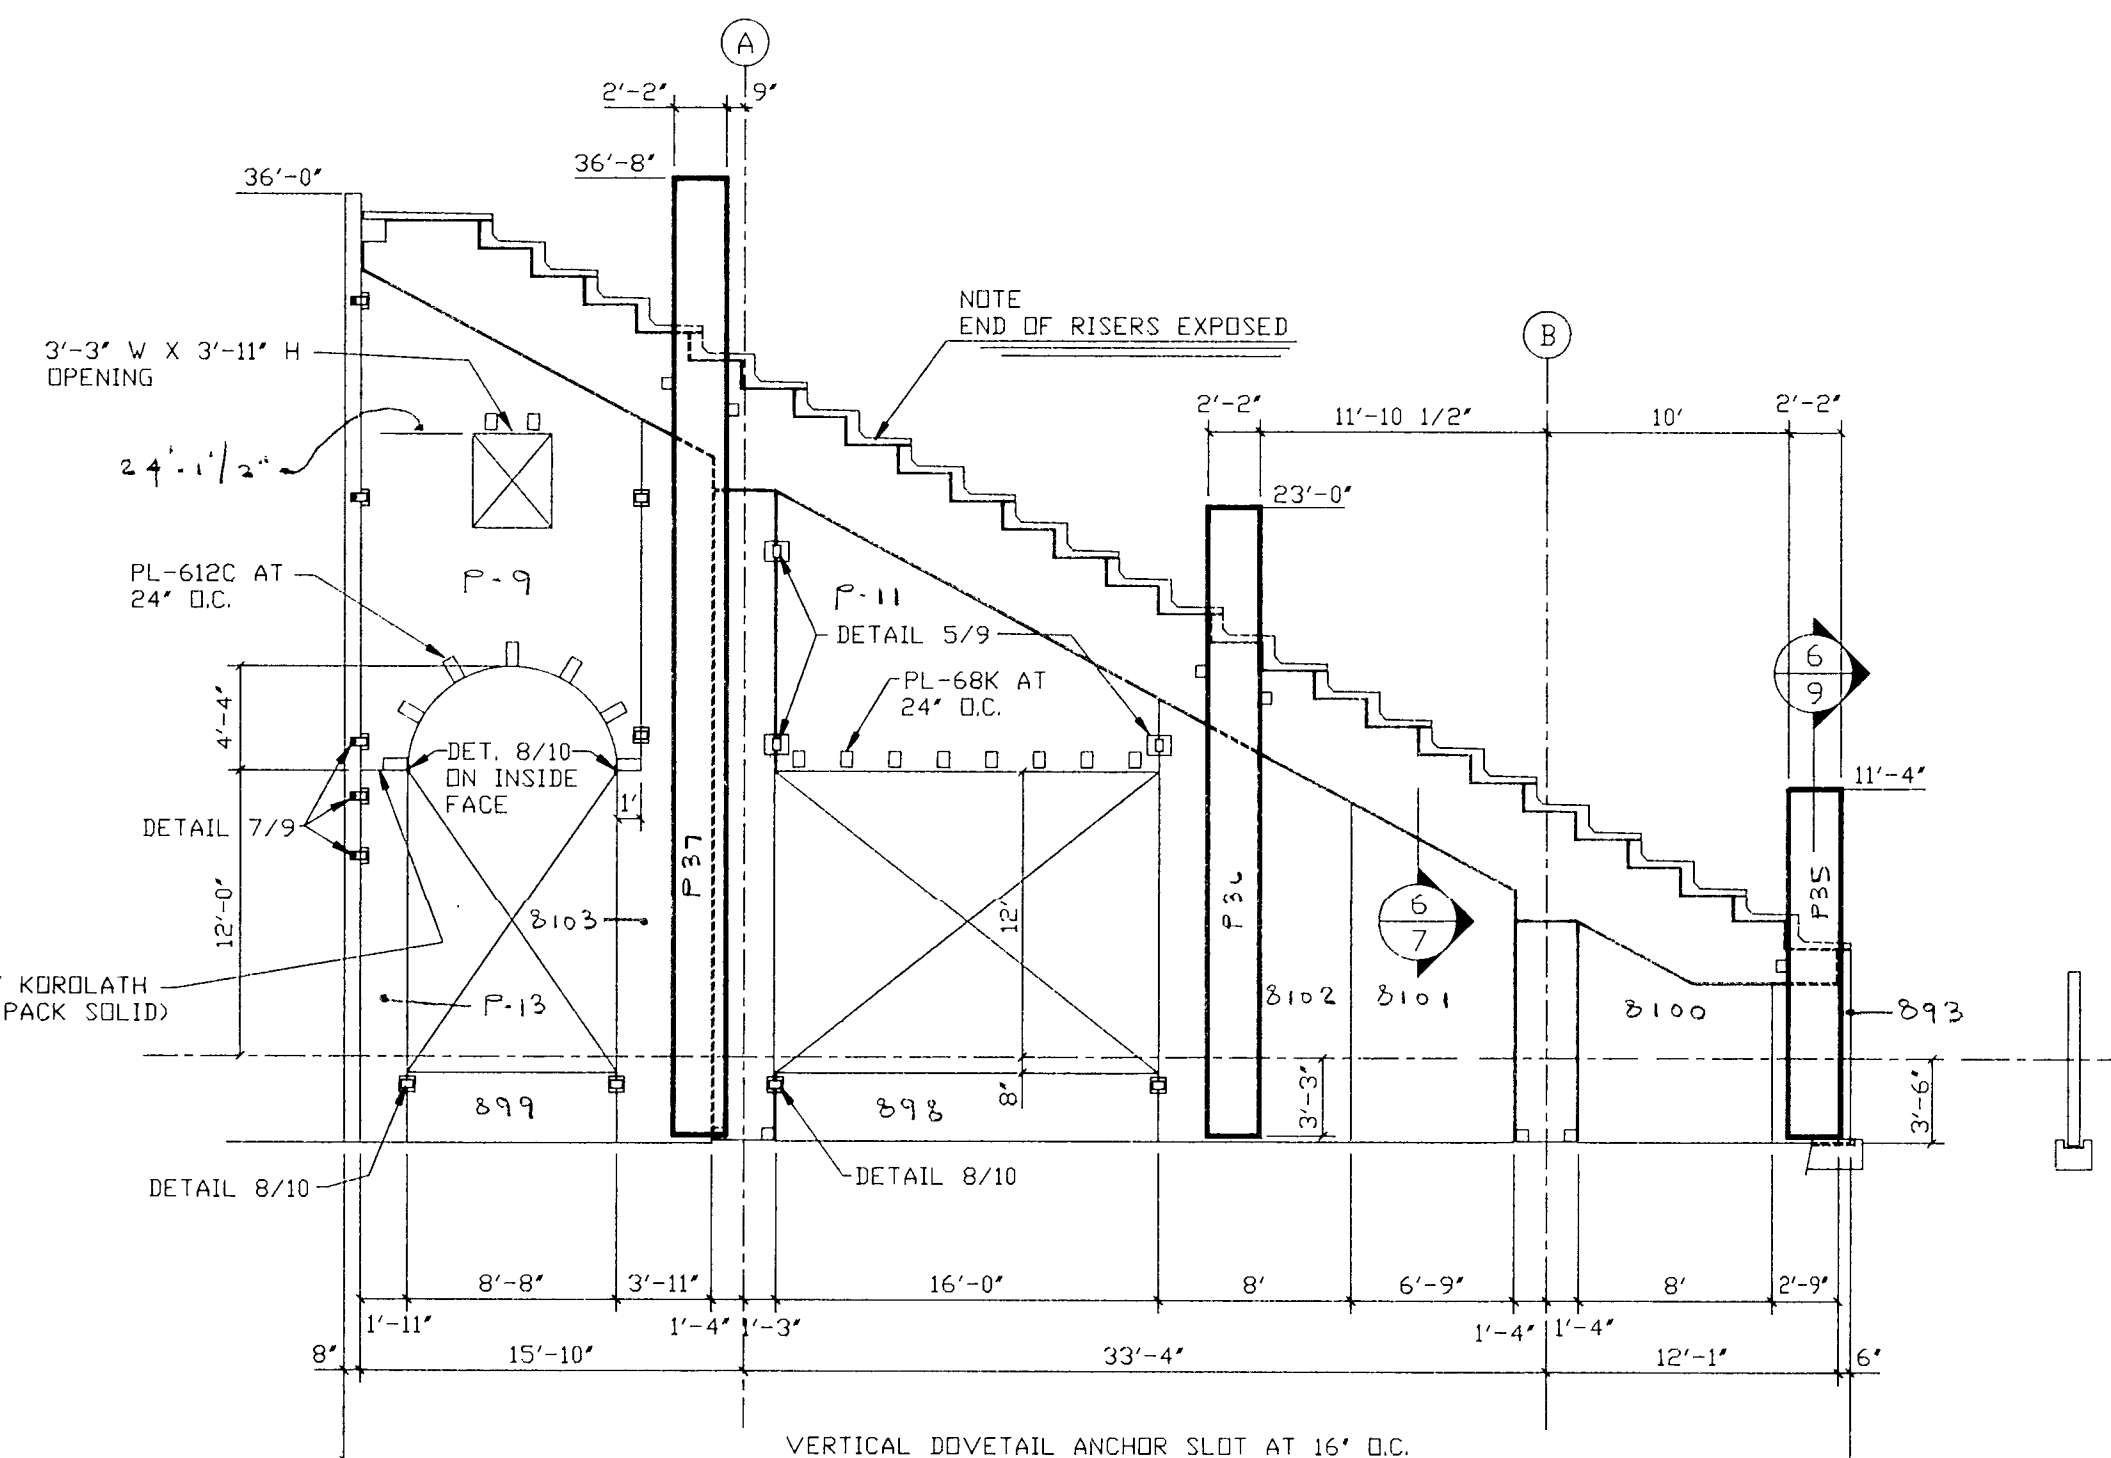


ELEVATION EAST END OF STADIUM


SCALE 1/8" = 1'-0"

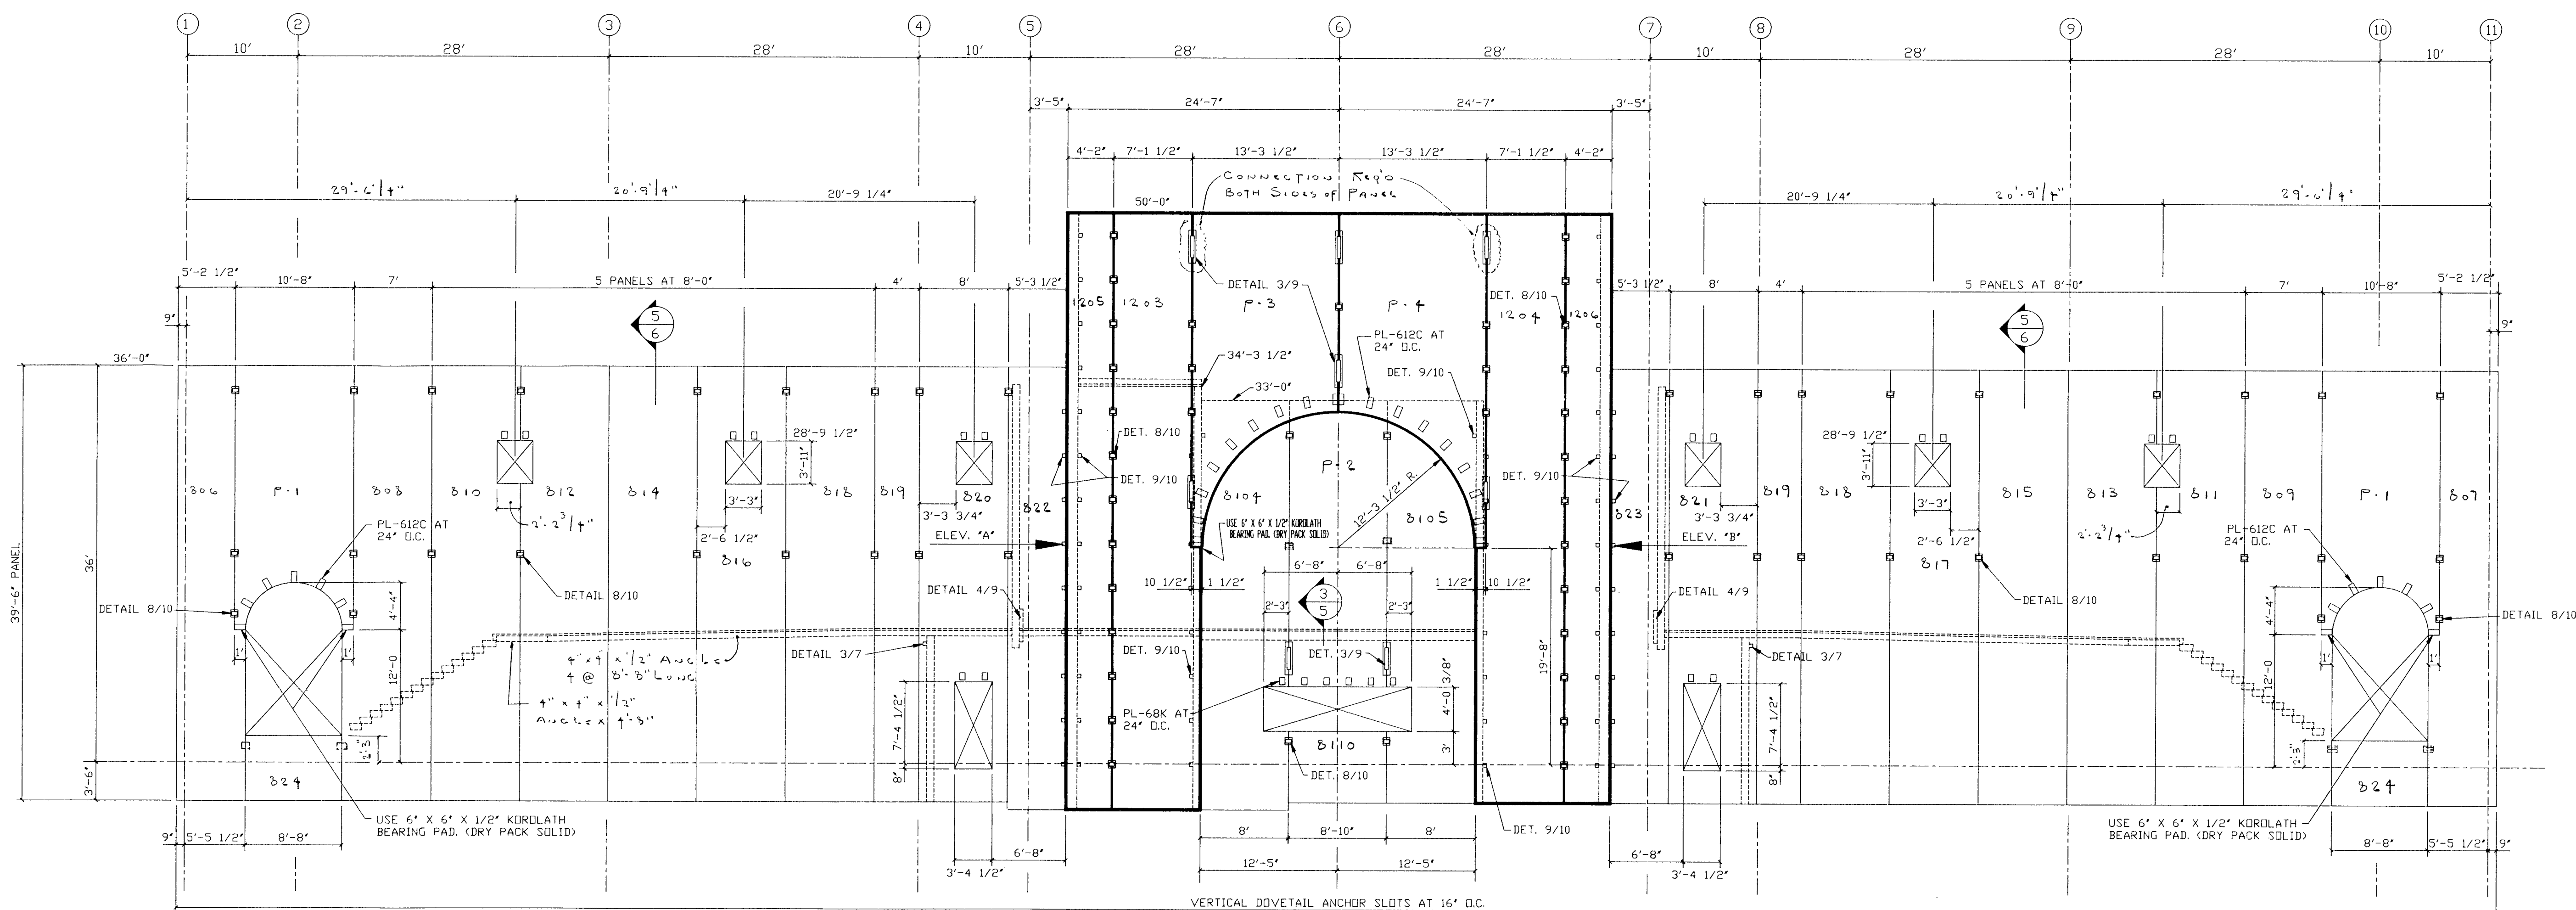


SOUTH ELEVATION OF STADIUM

SCALE 1/8" = 1'-0"

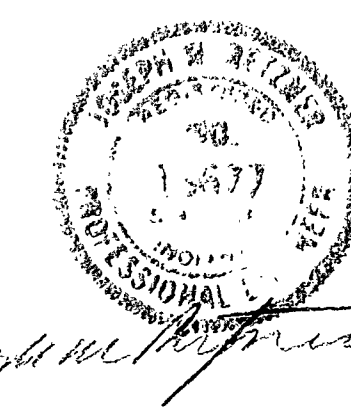

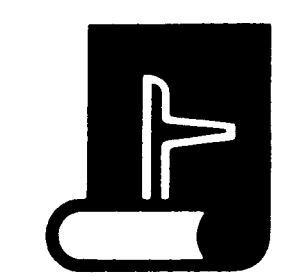

PROJECT FOR
AMERICAN PRECAST CONCRETE
PREPARED BY
PRECAST CONCRETE SYSTEMS, INC.
SUBSIDIARY OF AMERICAN PRECAST CONCRETE
1030 S. KITLEY AVE.
INDIANAPOLIS, INDIANA 46203

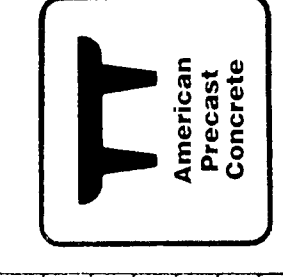

REVISIONS		REVISIONS		REVISIONS		REVISIONS	
NO.	DATE	BY	DATE	BY	DATE	BY	DATE
1	11/10/14	JVM					
2	11/10/14	JVM					

ARCHITECT
THE ODLE MCQUIRE & SHOOK CORPORATION

CONTRACTOR
CONSTRUCTION CONTROL

DRAWN BY
JVM

CHECKED BY
JVM

DATE
11/10/14


AMES FIELD
MICHIGAN CITY, IND.

JOB NO. **1195**

SHEET **8**


OF SHEETS

11/10/14

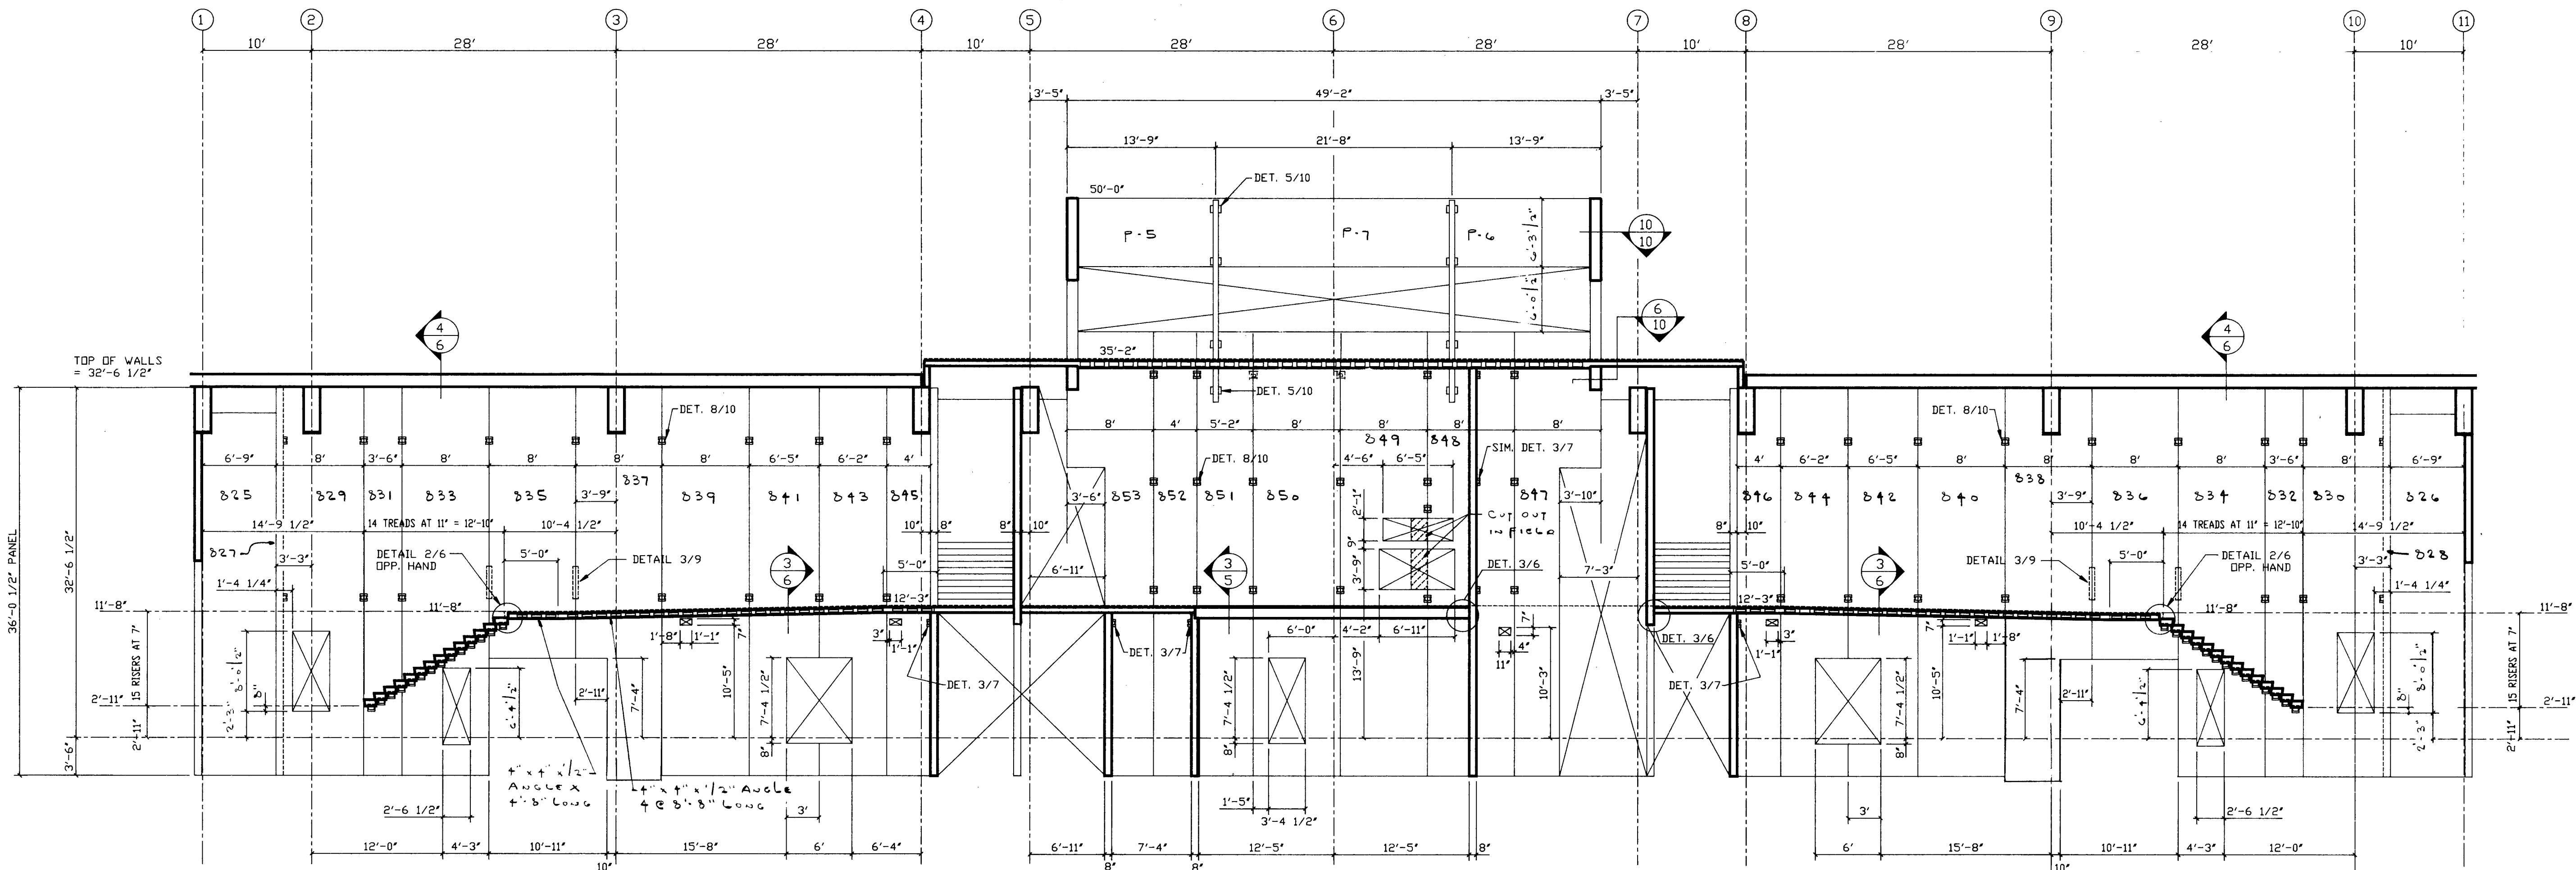


SECTION 1
9


SCALE 1/8" = 1'-0"

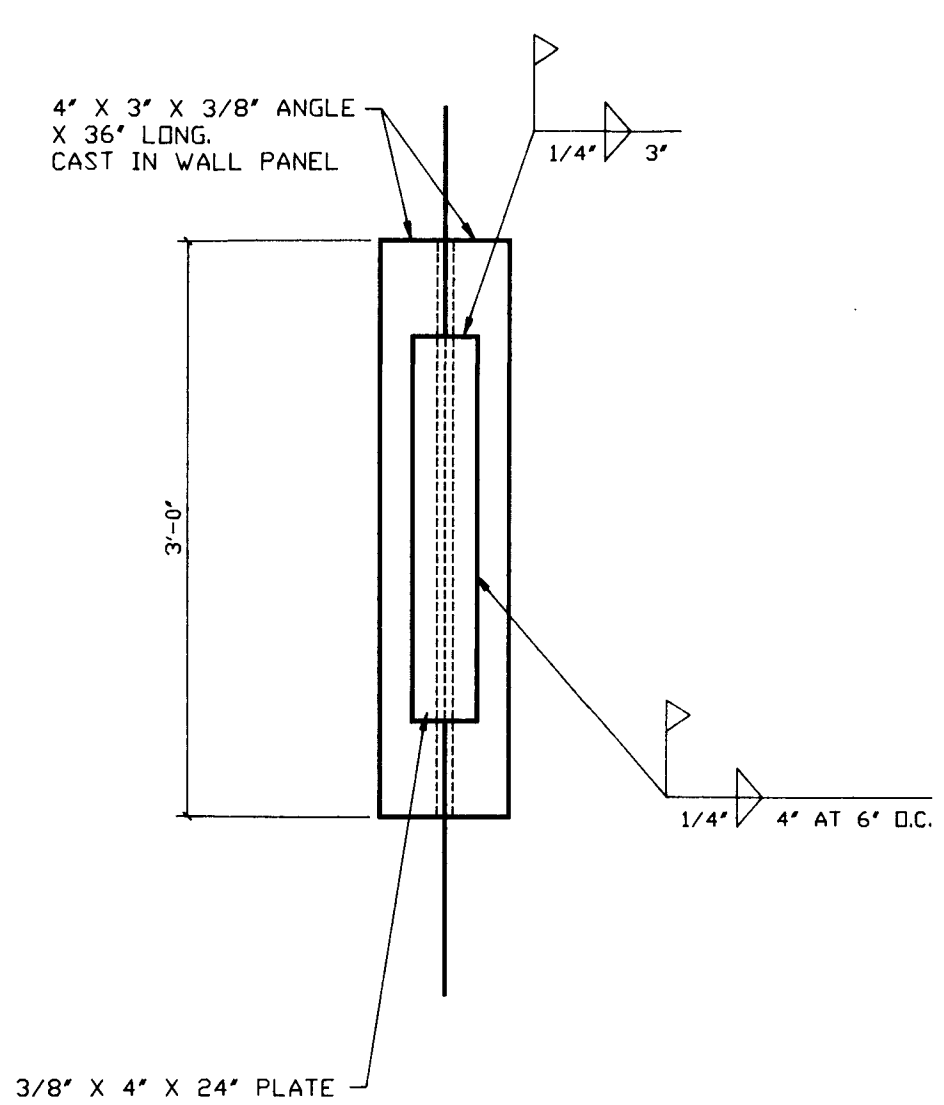


DETAIL 3
9

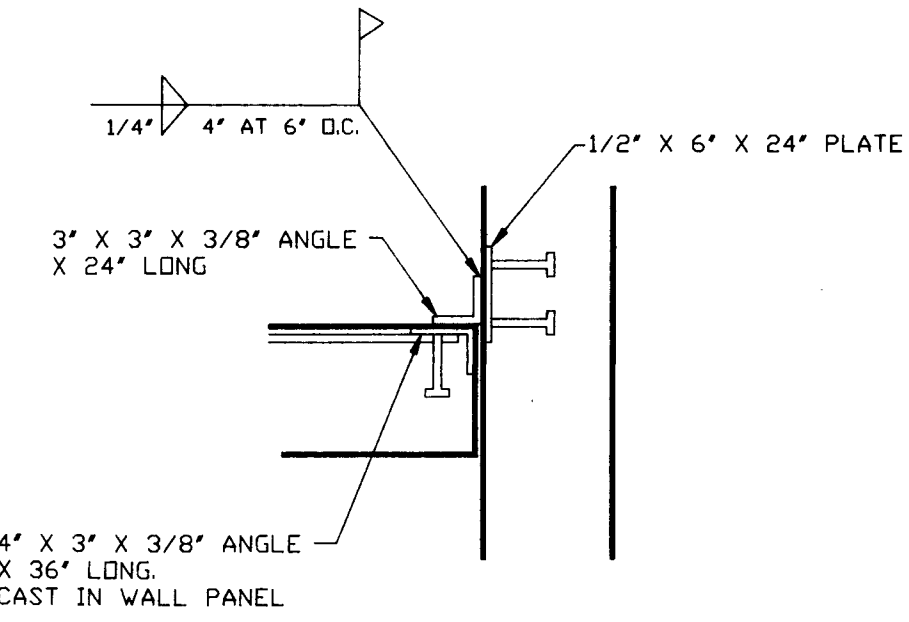


DETAIL 4
9

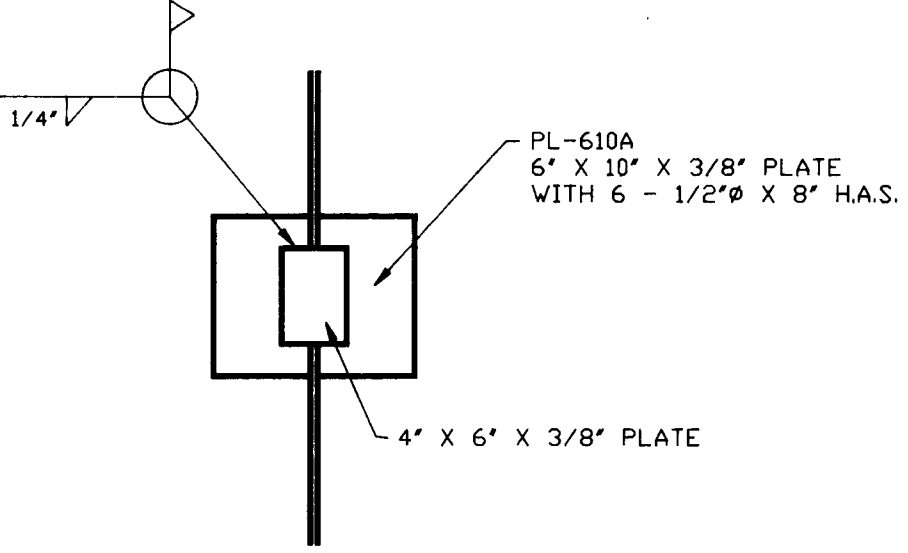


DETAIL 5
9

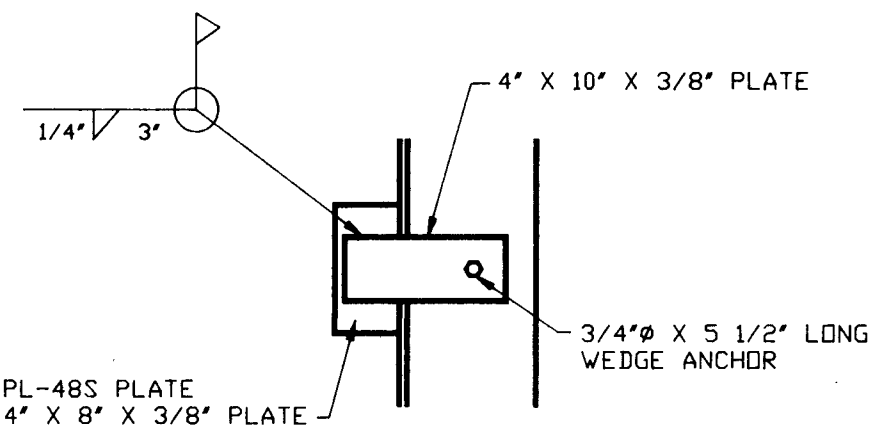


DETAIL 7
9

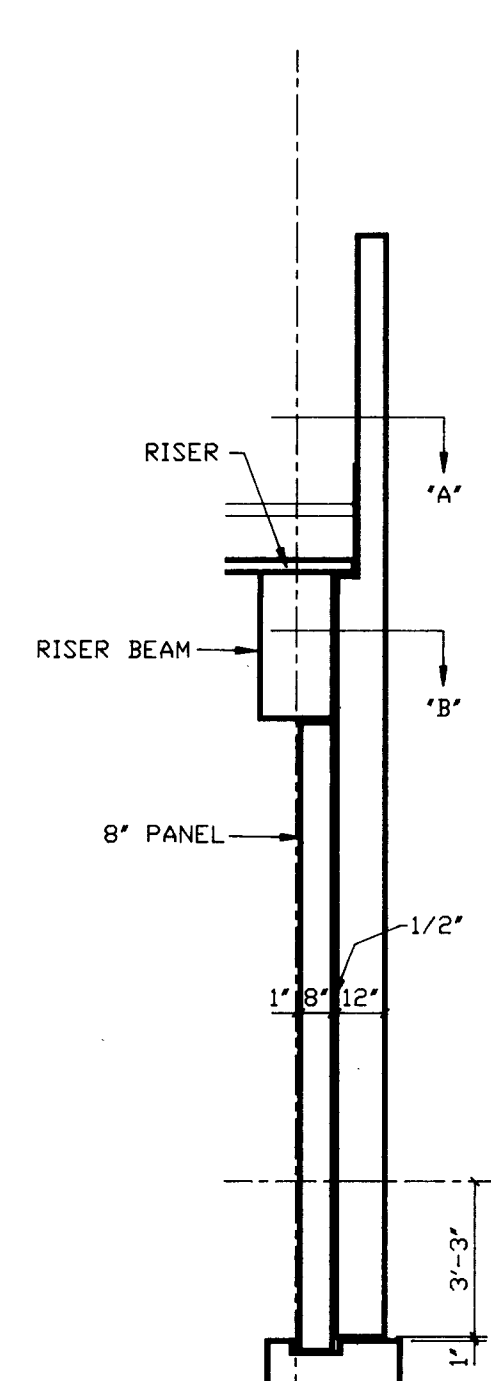

DETAIL 7
9

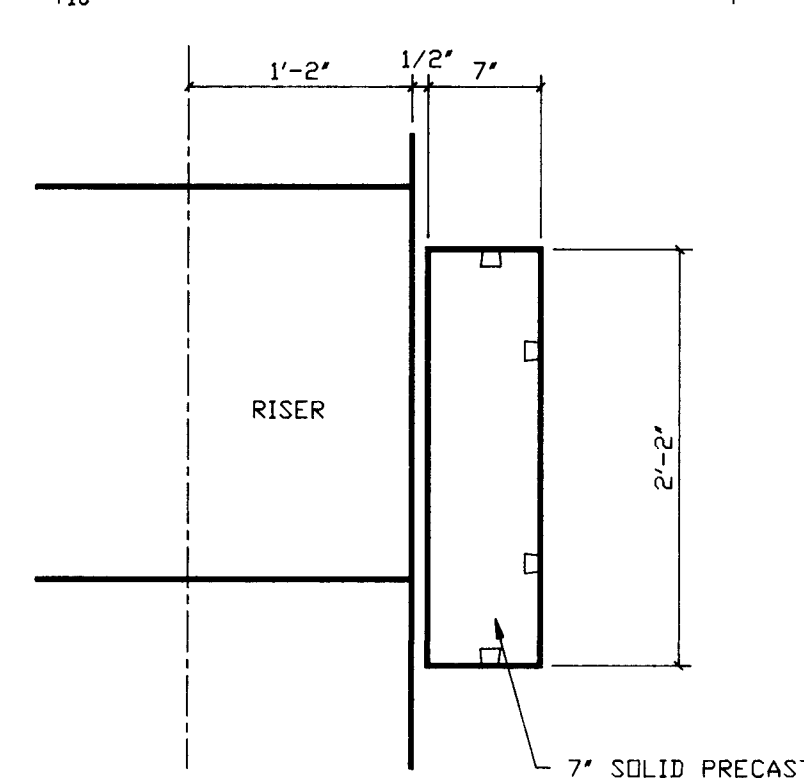

SECTION "A"

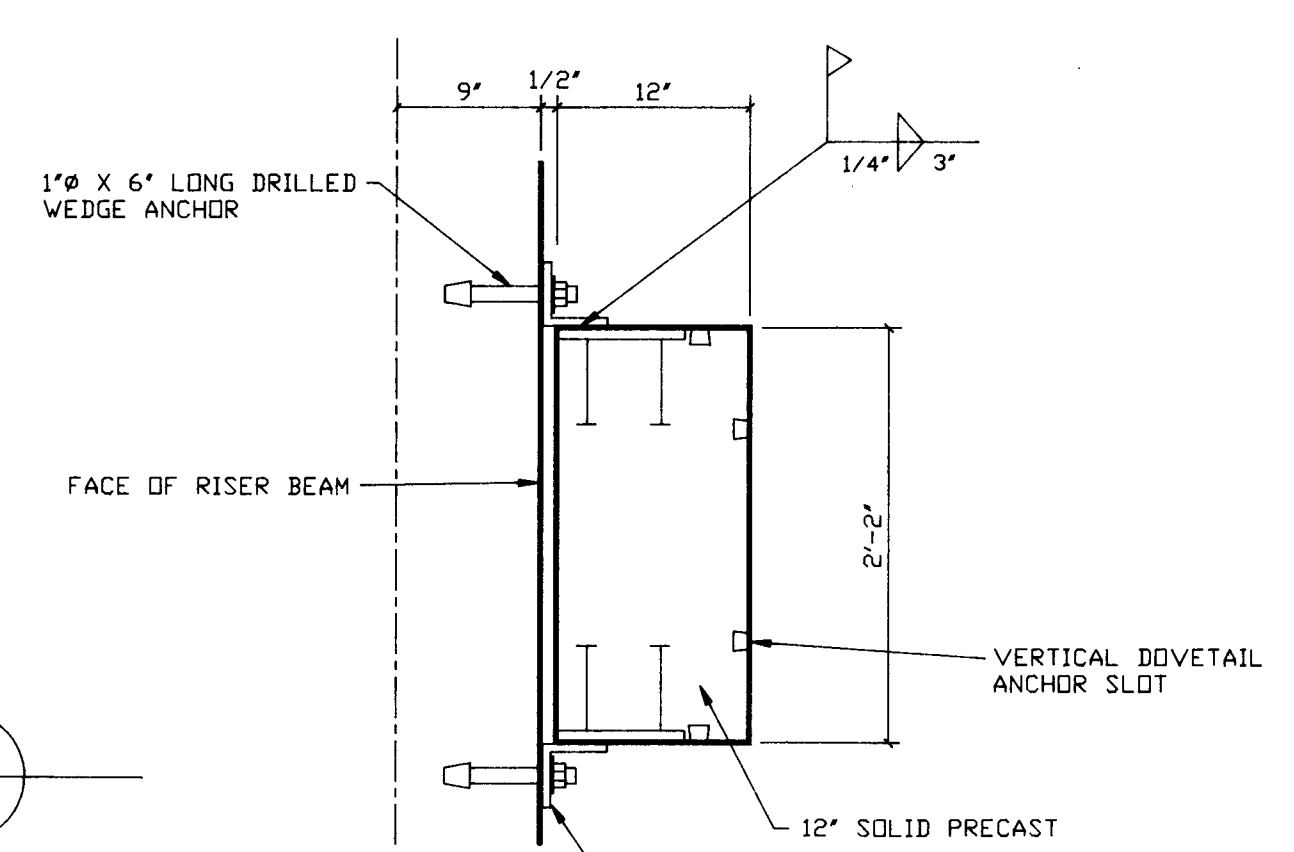

SECTION "B"



PROJECT FOR
AMERICAN PRECAST CONCRETE

PREPARED BY
PRECAST CONCRETE SYSTEMS, INC.

SUBSIDIARY OF AMERICAN PRECAST CONCRETE
1030 S. KITLEY AVE.
INDIANAPOLIS, INDIANA 46203

ARCHITECT
THE ODLE MCQUIRE & SHOOK CORPORATION

CONTRACTOR
CONSTRUCTION CONTROL

AMES FIELD
MICHIGAN CITY, IND.

REVISIONS		REVISIONS		REVISIONS		REVISIONS	
NO.	DATE	BY	DATE	BY	DATE	BY	DATE
1	8/23/94	ELM					
2	9/20/94	ELM					

JOB NO. 1195

SHEET 9

OF SHEETS

DATE 7/15/94

CHK BY JWR

DRAWN BY RM

