






MARION COUNTY NTS

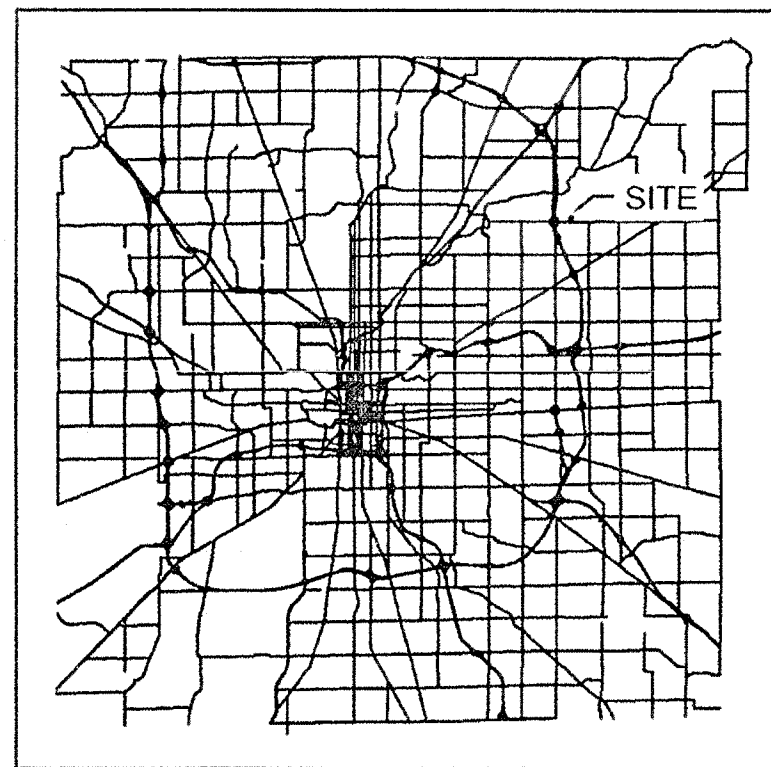

VICINITY MAP NTS

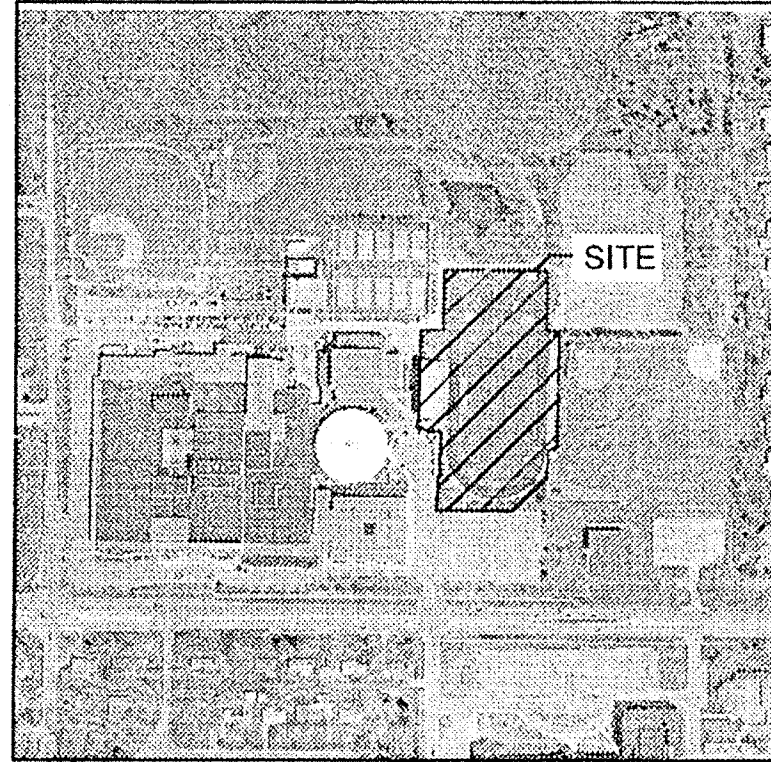


LOCATION MAP NTS

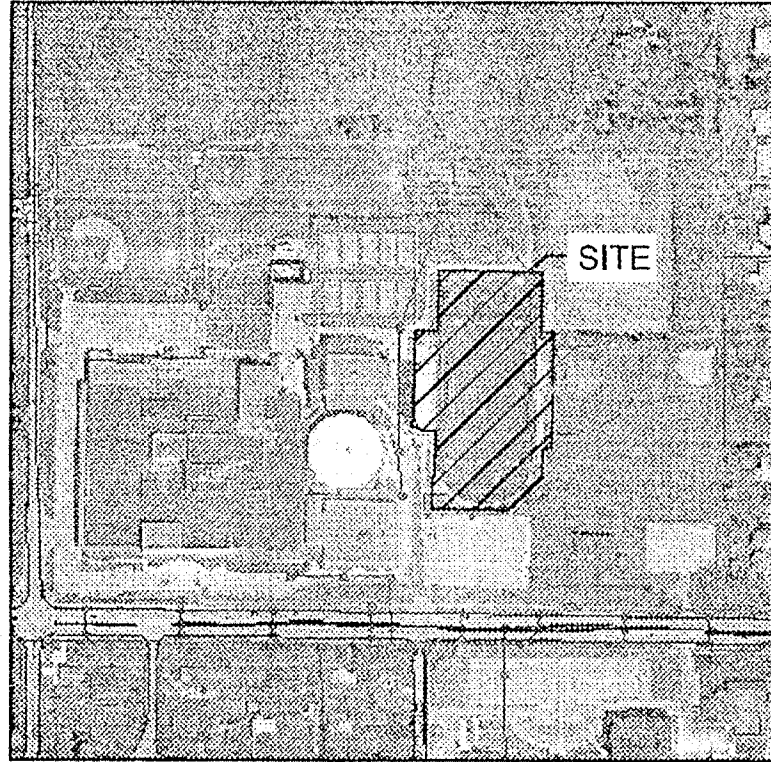

UNSEWERED AREA NTS

METROPOLITAN SCHOOL DISTRICT OF LAWRENCE TOWNSHIP RECORD DRAWINGS ~~CONSTRUCTION~~ PLANS FOR LAWRENCE CENTRAL HIGH SCHOOL ATHLETIC FIELD IMPROVEMENTS INDIANAPOLIS, INDIANA

LAWRENCE TOWNSHIP, MARION COUNTY
SECTION 1, TOWNSHIP 16 N, RANGE 4 E

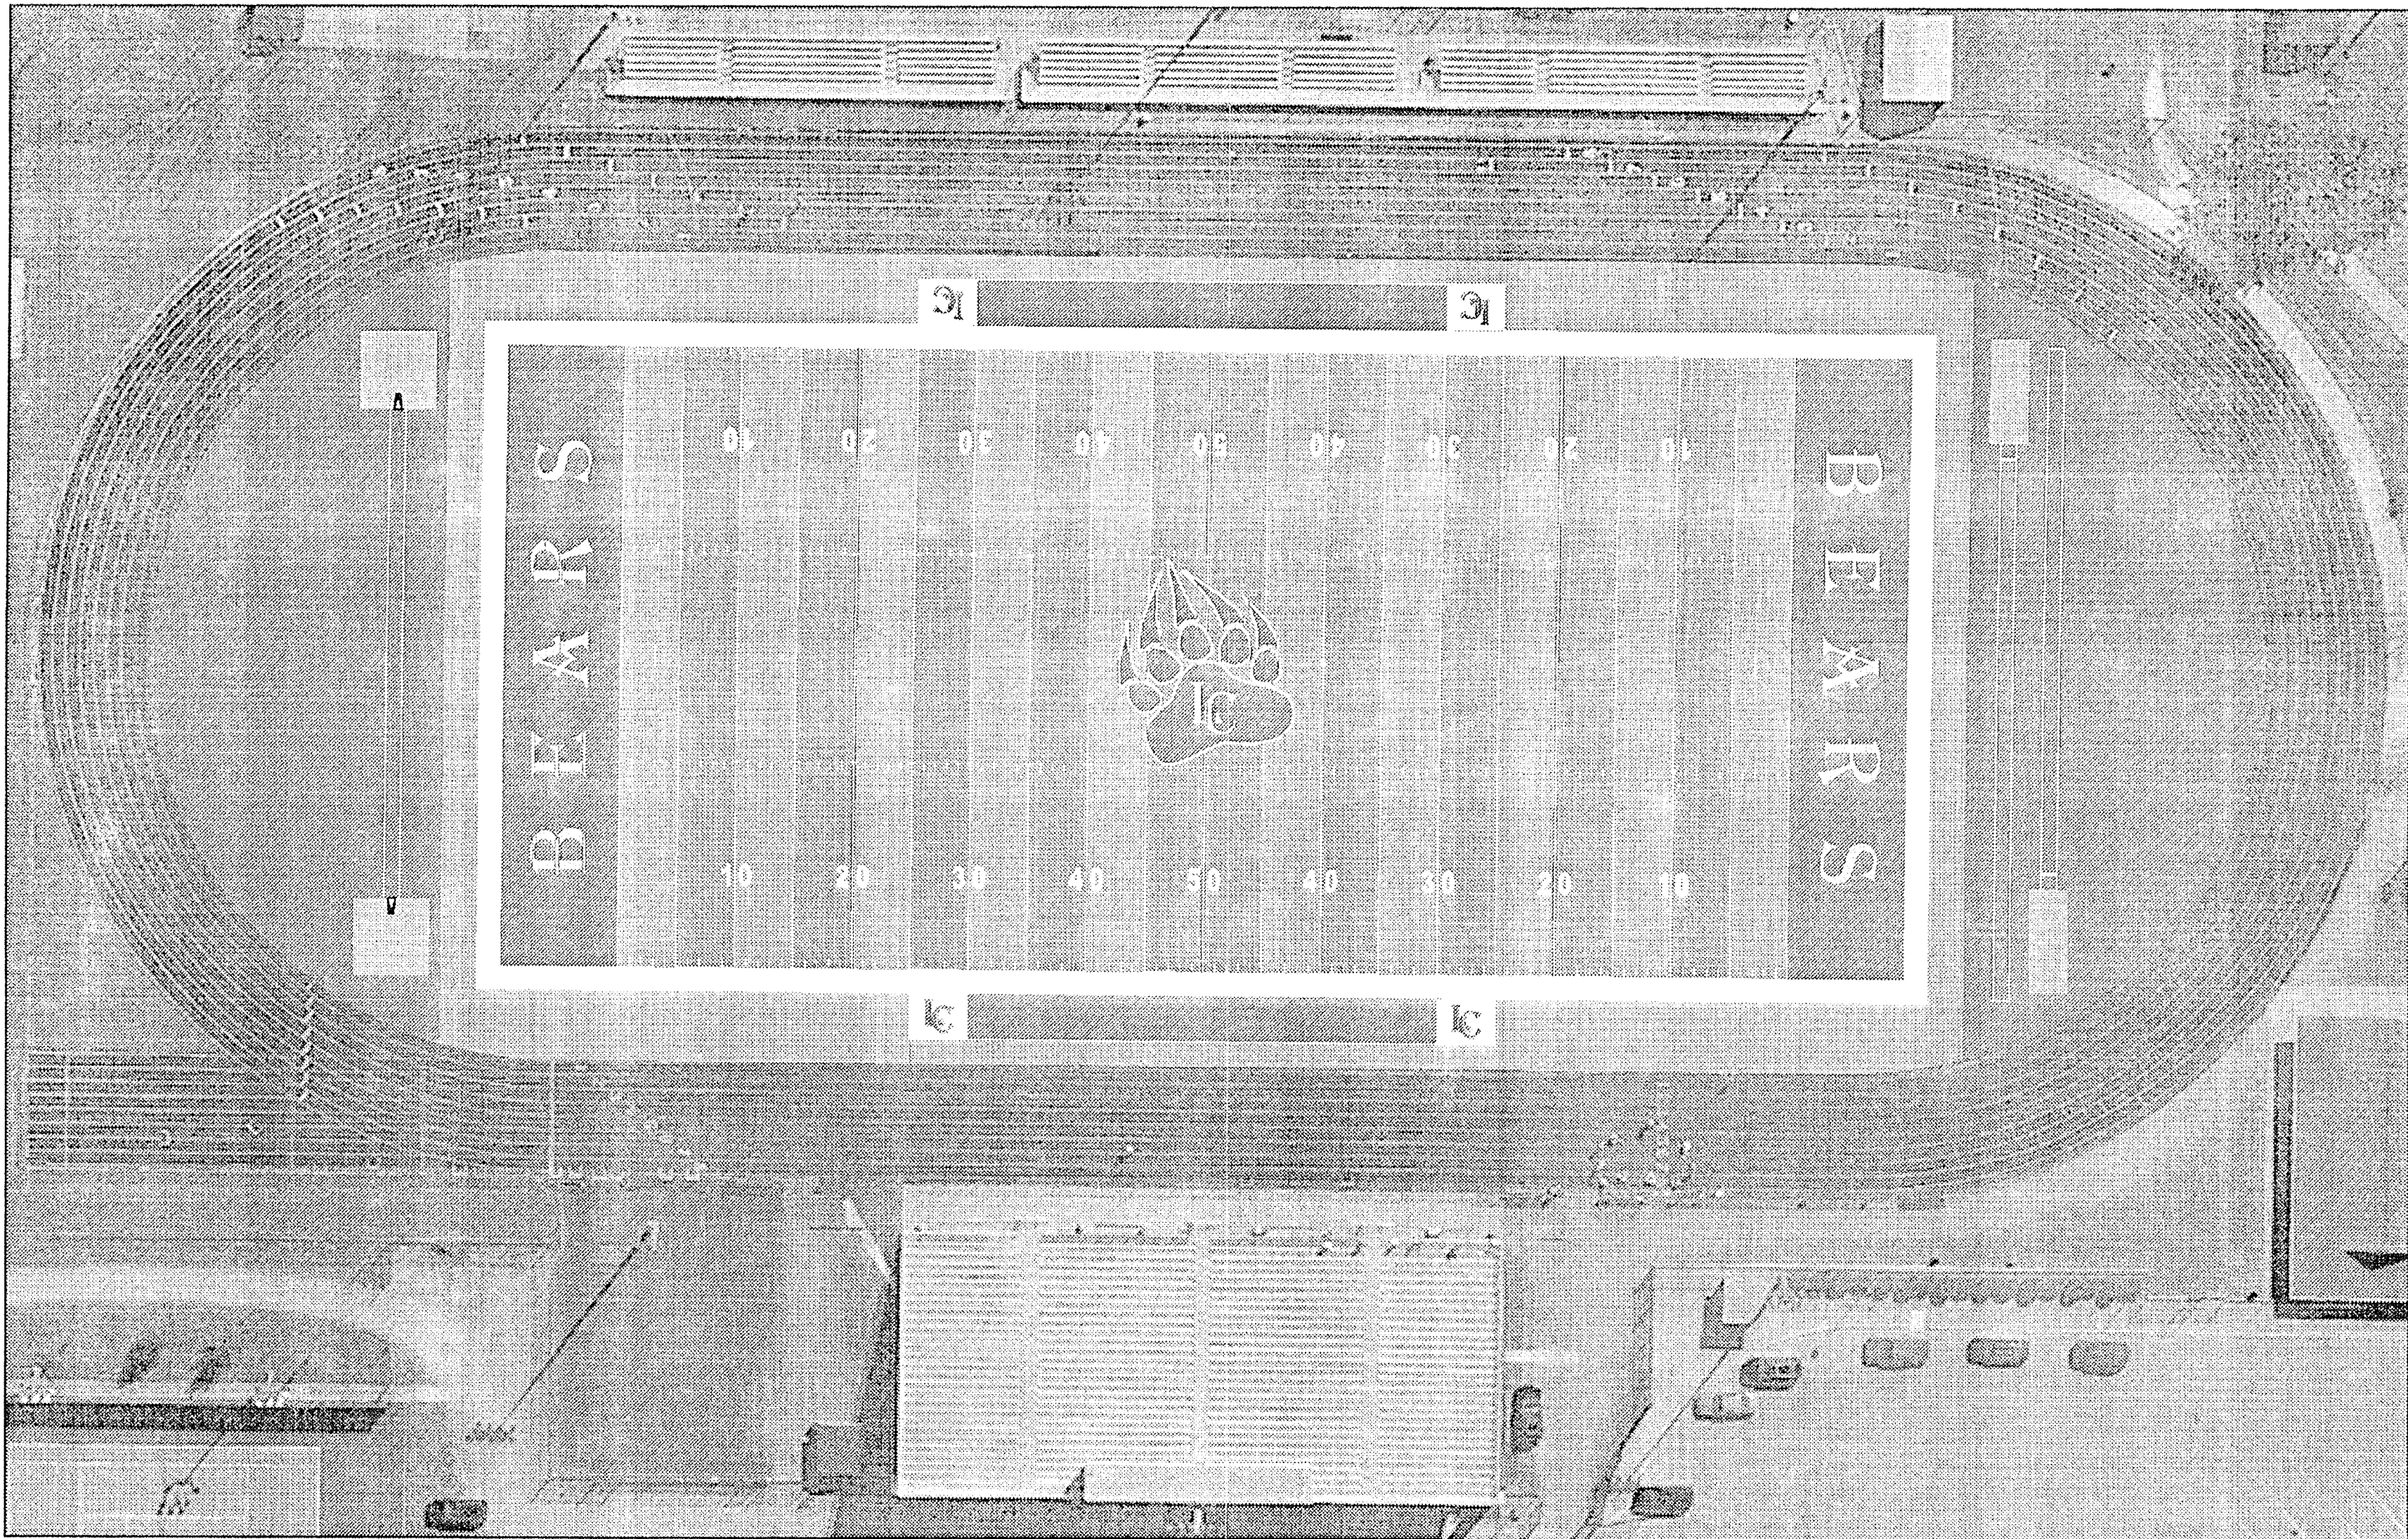


PROPOSED SITE NTS

The as-built field work was performed by SEA GROUP LLC,
Land Surveyors under my direct supervision and direction.
Items with a line struck through them are the proposed
items per the Original Construction Plans, Signed by
Kashif J. Khan PE, which are certified April 25, 2008.

Brian C. Rasmiller

Brian C. Rasmiller
Registered Land Surveyor
Indiana No. LS20200083
SEA Group, Land Surveyors
494 Grady Dr. Carmel, IN 46032
(317) 844-3333

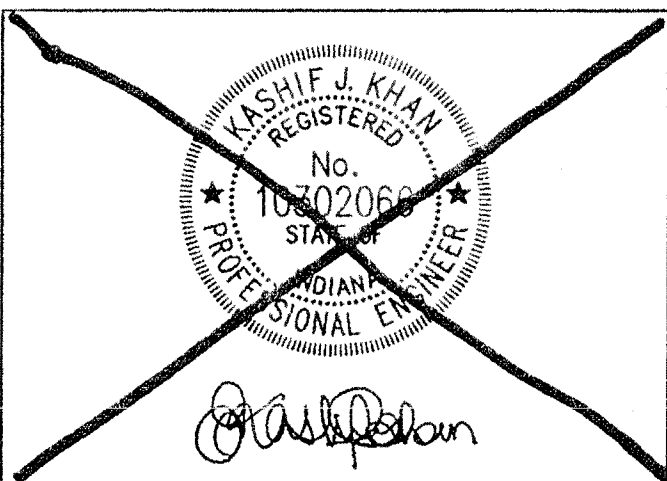

SHEET INDEX:

S-000	TITLE SHEET
S-101	EXISTING CONDITIONS & DEMOLITION PLAN
S-201	SITE & GRADING PLAN
S-202	PROFILE AND CROSS SECTIONS
S-301	STORM DRAINAGE PLAN
S-302	UTILITY PLAN
S-401	EROSION CONTROL & CONSTRUCTION ACCESS PLAN
S-402	EROSION CONTROL DETAILS
S-403	EROSION CONTROL DETAILS
S-500	FIELD LAYOUT
S-501	STANDARD DETAILS
THRU	
S-506	
ADDED AS BUILT FACE OF CURB/SAW CUT SHEET	


ADDED DETAIL SHEET 5/9/08



Construction Plans For Athletic Field Improvements Lawrence Central High School Metropolitan School District of Lawrence Township

INFRASTRUCTURE ENGINEERING, INC.
2801 FORTUNE CIRCLE EAST, SUITE 201C
INDIANAPOLIS, IN 46241
PHONE: 317.243.9800
info@infrastructure-eng.com

TITLE SHEET	
Project	08-2052
Date	APRIL 25, 2008
Scale	N/A
Sheet Number	S-000

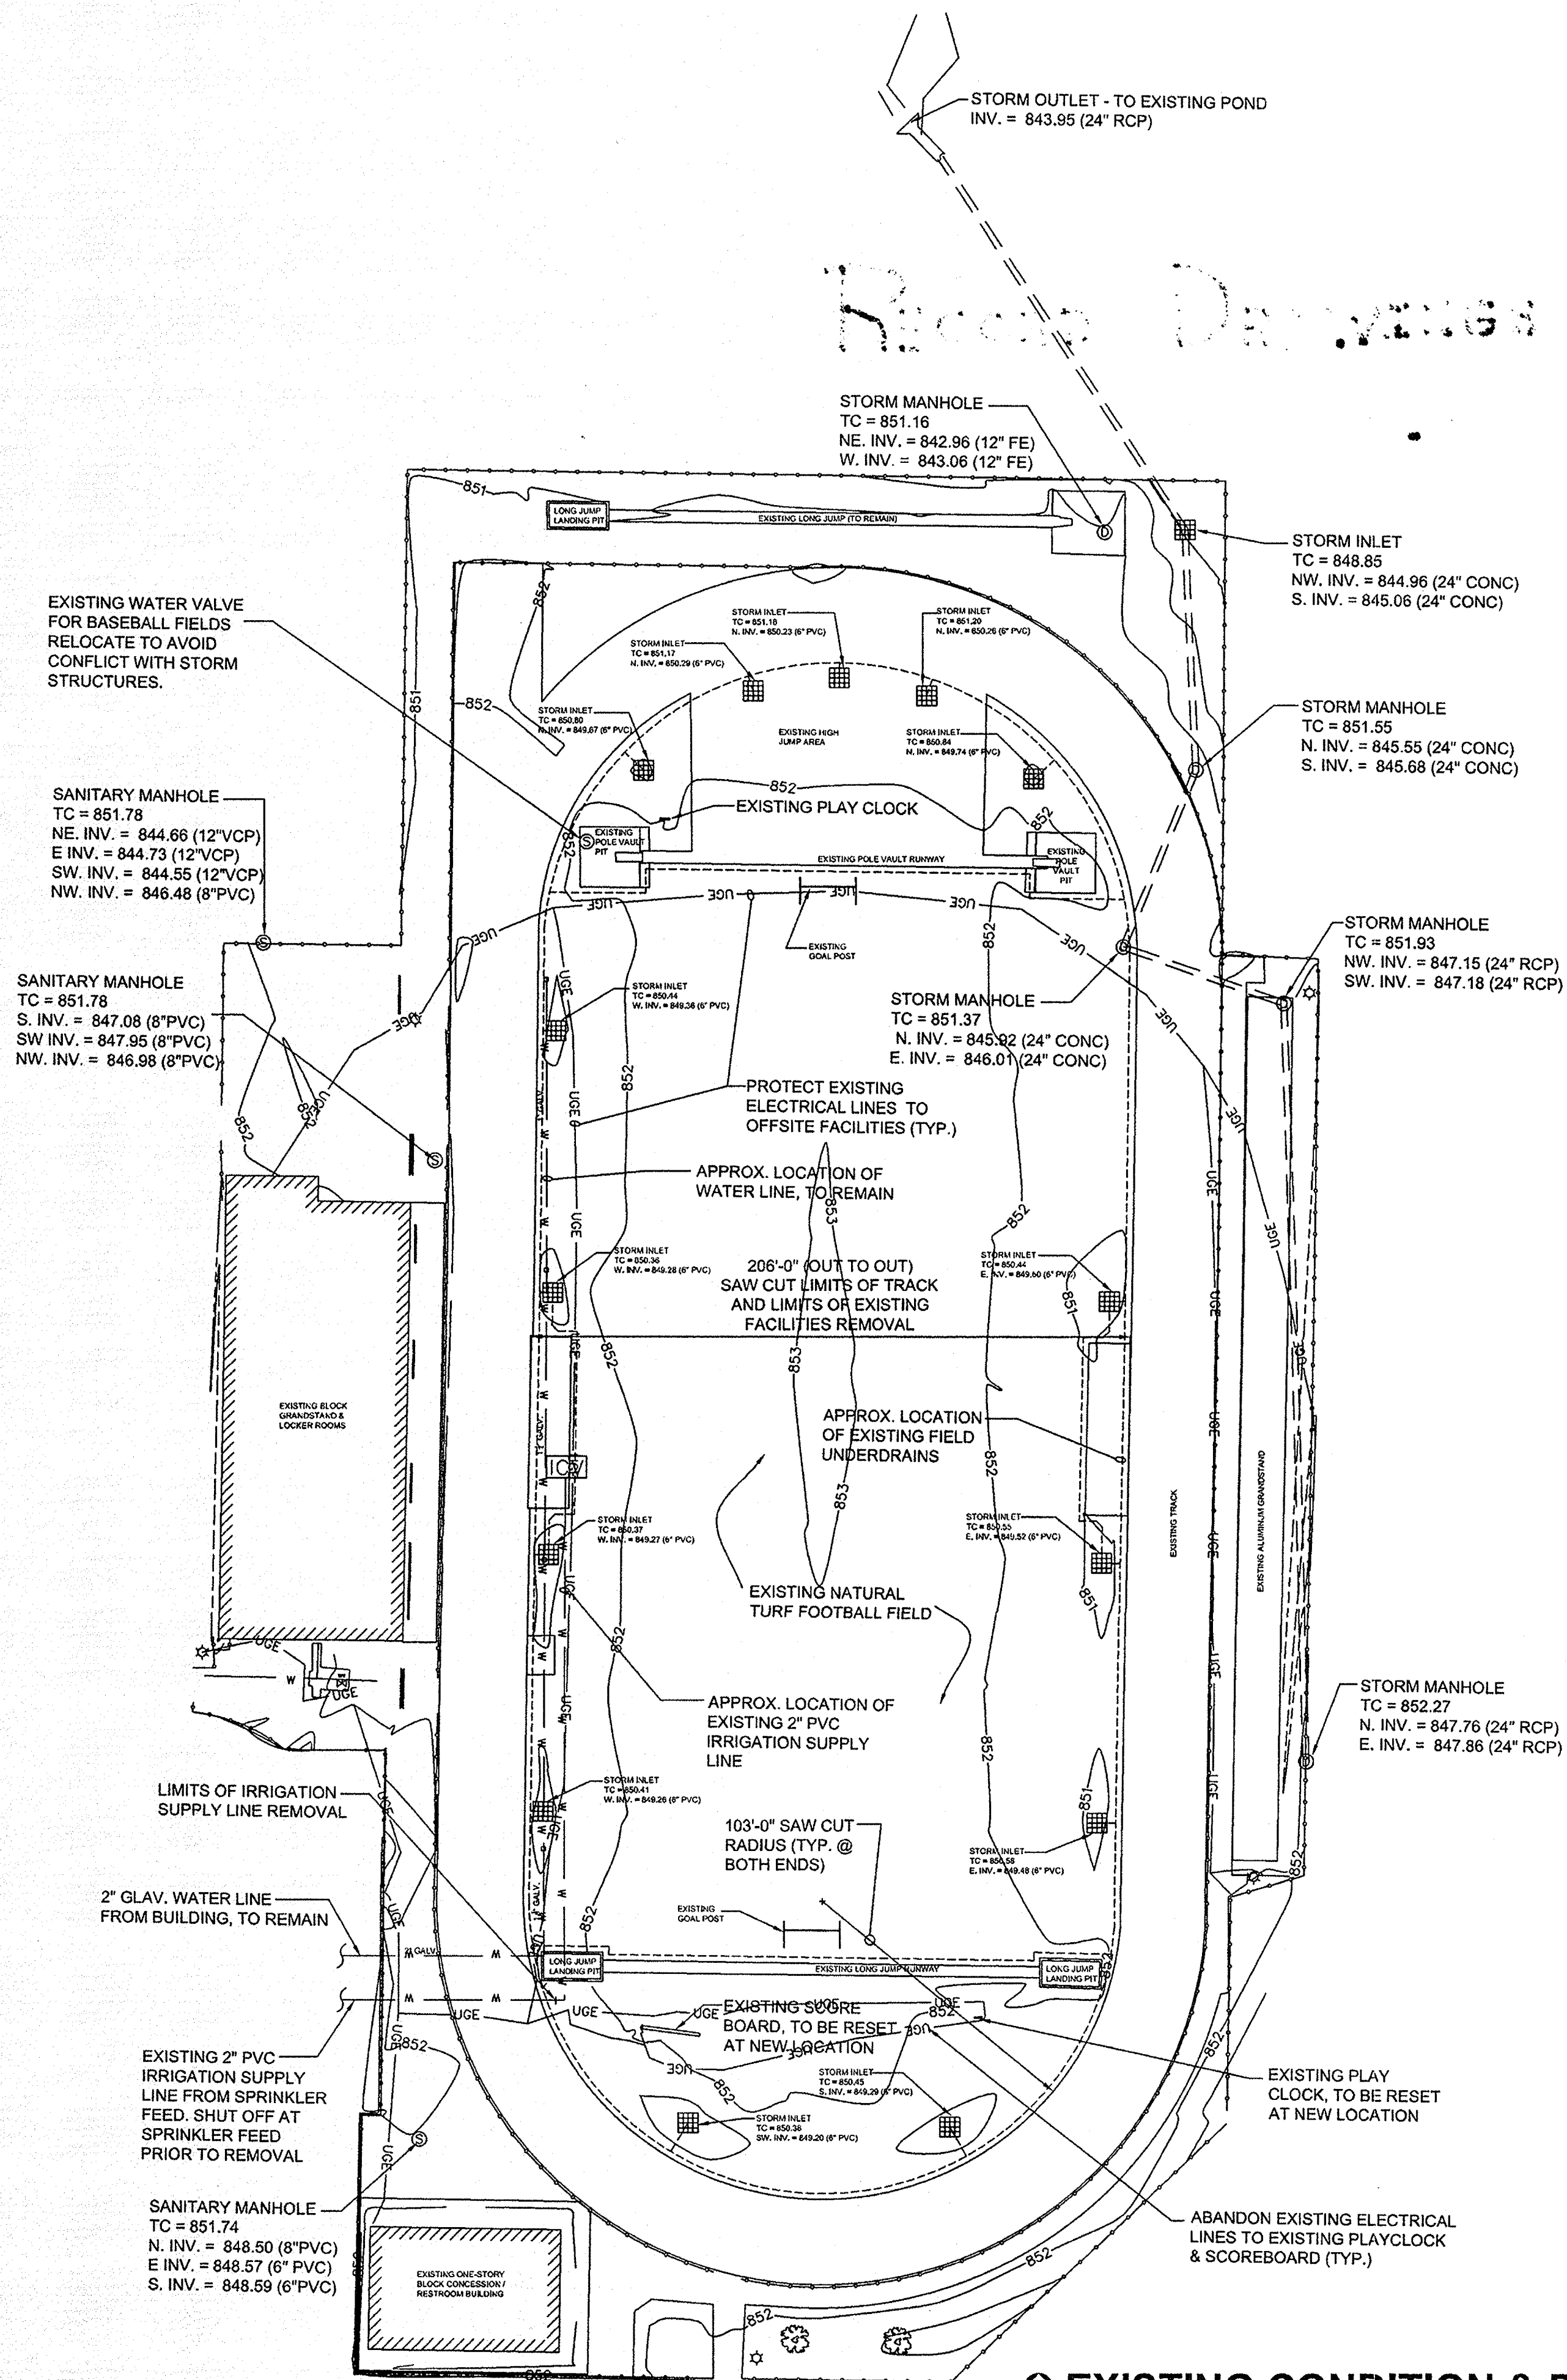

EXISTING CONDITION & DEMOLITION PLAN

GENERAL NOTES

- 1) ALL FACILITIES INSIDE THE TRACK SHALL BE REMOVED UNLESS NOTED OTHERWISE OR AS DIRECTED BY THE ENGINEER
- 2) EXISTING IRRIGATION SYSTEM SHALL BE REMOVED INCLUDING THE VALVE BOX SYSTEM. IRRIGATION SYSTEM NOT FULLY SHOWN FOR PLAN CLARITY. LIMITS OF REMOVAL SHALL BE TO THE PROPOSED LOCATION OF THE NEW 2" PVC PIPE FOR QUICK COUPLING VALVE.
- 3) PRIOR TO SAWCUTTING OF EXISTING TRACK, CONTRACTOR SHALL VERIFY THAT THE RESULTING CLEAR WIDTH WILL PROVIDE THE PROPOSED SYNTHETIC TURF DIMENSIONS AS INDICATED ON THE SITE PLAN. ANY DISCREPANCIES SHALL BE BROUGHT TO THE ATTENTION OF THE ENGINEER PRIOR TO START OF SAW CUTTING
- 4) ANY UNDERGROUND UTILITIES DEPICTED ON THE ATTACHED DRAWINGS HAVE BEEN LOCATED PER FIELD OBSERVATIONS AND/OR MARKINGS BY A PRIVATE LOCATOR (BLOODHOUND UNDERGROUND). NO WARRANTY, EITHER EXPRESSED OR IMPLIED, IS MADE TO THE ACCURACY AND/OR COMPLETENESS OF INFORMATION PRESENTED ON UNDERGROUND UTILITIES, OR AS TO ITS FITNESS FOR ANY PARTICULAR PURPOSE OR USE. IN NO EVENT WILL INFRASTRUCTURE ENGINEERING INC., ITS SUBCONSULTANTS, ITS EMPLOYEES, AGENTS, AND/OR ASSIGNS BE LIABLE FOR ANY DAMAGES ARISING OUT OF THE FURNISHING AND/OR USE OF SUCH INFORMATION. THE PATH OF THE UTILITY LINES SHOWN HEREON SHOULD BE CONSIDERED APPROXIMATE UNTIL THEY ARE EITHER RELOCATED, BY CALLING THE INDIANA PLANT PROTECTION AGENCY AT 1-800-382-5544, BLOODHOUND UNDERGROUND AT 1-888-858-8830 OR UNTIL THEY ARE EXCAVATED TO VERIFY THE EXACT LOCATION AND PATH OF THE UTILITY LINES.
- 5) REMOVE FOUNDATIONS FOR THE REMOVED FACILITIES A MINIMUM OF TWO FEET (2') BELOW FINISHED GRADE, UNLESS DIRECTED OTHERWISE BY THE ENGINEER.

PERMANENT BENCHMARK

1) IDNR TBM HIMUSA 4 1989 MARION COUNTY, FISHERS QUAD, SE/SEC. 24, T17N, R4E: LOCATED NEAR THE INTERSECTION OF EAST 82nd STREET AND NORTH CASTLE LAKE ROAD, 0.5 MILES EAST OF INTERSECTION OF EAST 82nd STREET AND NORTH HAUGE ROAD, SET IN THE NORTH SIDE OF UTILITY POLE #55-250-A, 24.0 FEET SOUTH OF EAST 82nd STREET CENTERLINE, 94.0 FEET WEST OF NORTH CASTLE LAKE ROAD CENTERLINE, 1.3 FEET ABOVE GROUND LEVEL; A RAILROAD SPIKE DRIVEN THROUGH AN ALUMINUM TAG, STAMPED "HIMUSA 4 1989" ELEV.= 839.430 (NGVD 1929)

FLOOD ZONE DESIGNATION:

1) THIS LOT LIES PARTIALLY/ENTIRELY IN FLOOD HAZARD ZONE X AS SCALED FROM THE FLOOD INSURANCE RATE MAP FOR MARION COUNTY, INDIANA. COMMUNITY NAME, CITY OF INDIANAPOLIS, COMMUNITY NUMBER, 180159, PANEL NUMBER, 0088E.

SYMBOL LEGEND

- ELECTRIC TRANSFORMER
- ELECTRIC PEDESTAL
- GAS METER
- TELEPHONE MANHOLE
- MANHOLE
- TREE
- PIPE BALLARD
- HANDICAP PARKING
- DROP ELECTRIC OFF OF POLE
- ELECTRIC MANHOLE
- REBAR FOUND
- STORM INLET
- GAS VALVE
- WATER VALVE
- WATER METER
- SIGN
- LIGHT
- UTILITY POLE
- DRAINAGE INLET
- TELEPHONE PEDESTAL
- EXISTING DRAINAGE PIPE
- IRRIGATION CONTROL BOX
- UTILITY POINT OF SERVICE
- AIR CONDITIONING UNIT
- STRAIN POLE
- MONUMENT FOUND
- MANHOLE
- NOT IDENTIFIED
- TRAFFIC SIGNAL POLE
- FIRE HYDRANT
- GOAL POST



Kashif J. Khan

No.	Revision/Issue	Date

INFRASTRUCTURE ENGINEERING, INC.
2801 FORTUNE CIRCLE EAST,
SUITE 201C
INDIANAPOLIS, IN 46241
PHONE: 317.243.9800
info@infrastructure-eng.com


METROPOLITAN SCHOOL DISTRICT OF
LAWRENCE TOWNSHIP

CONSTRUCTION PLANS
LAWRENCE CENTRAL HIGH SCHOOL
ATHLETIC FIELD IMPROVEMENTS

7300 East 56th Street
Indianapolis, IN 46226

Sheet Name EX. COND. & DEMO. PLAN	Sheet Number
Project 08-2052	
Date APRIL 25, 2008	
Scale 1 INCH = 40 FEET	S-101




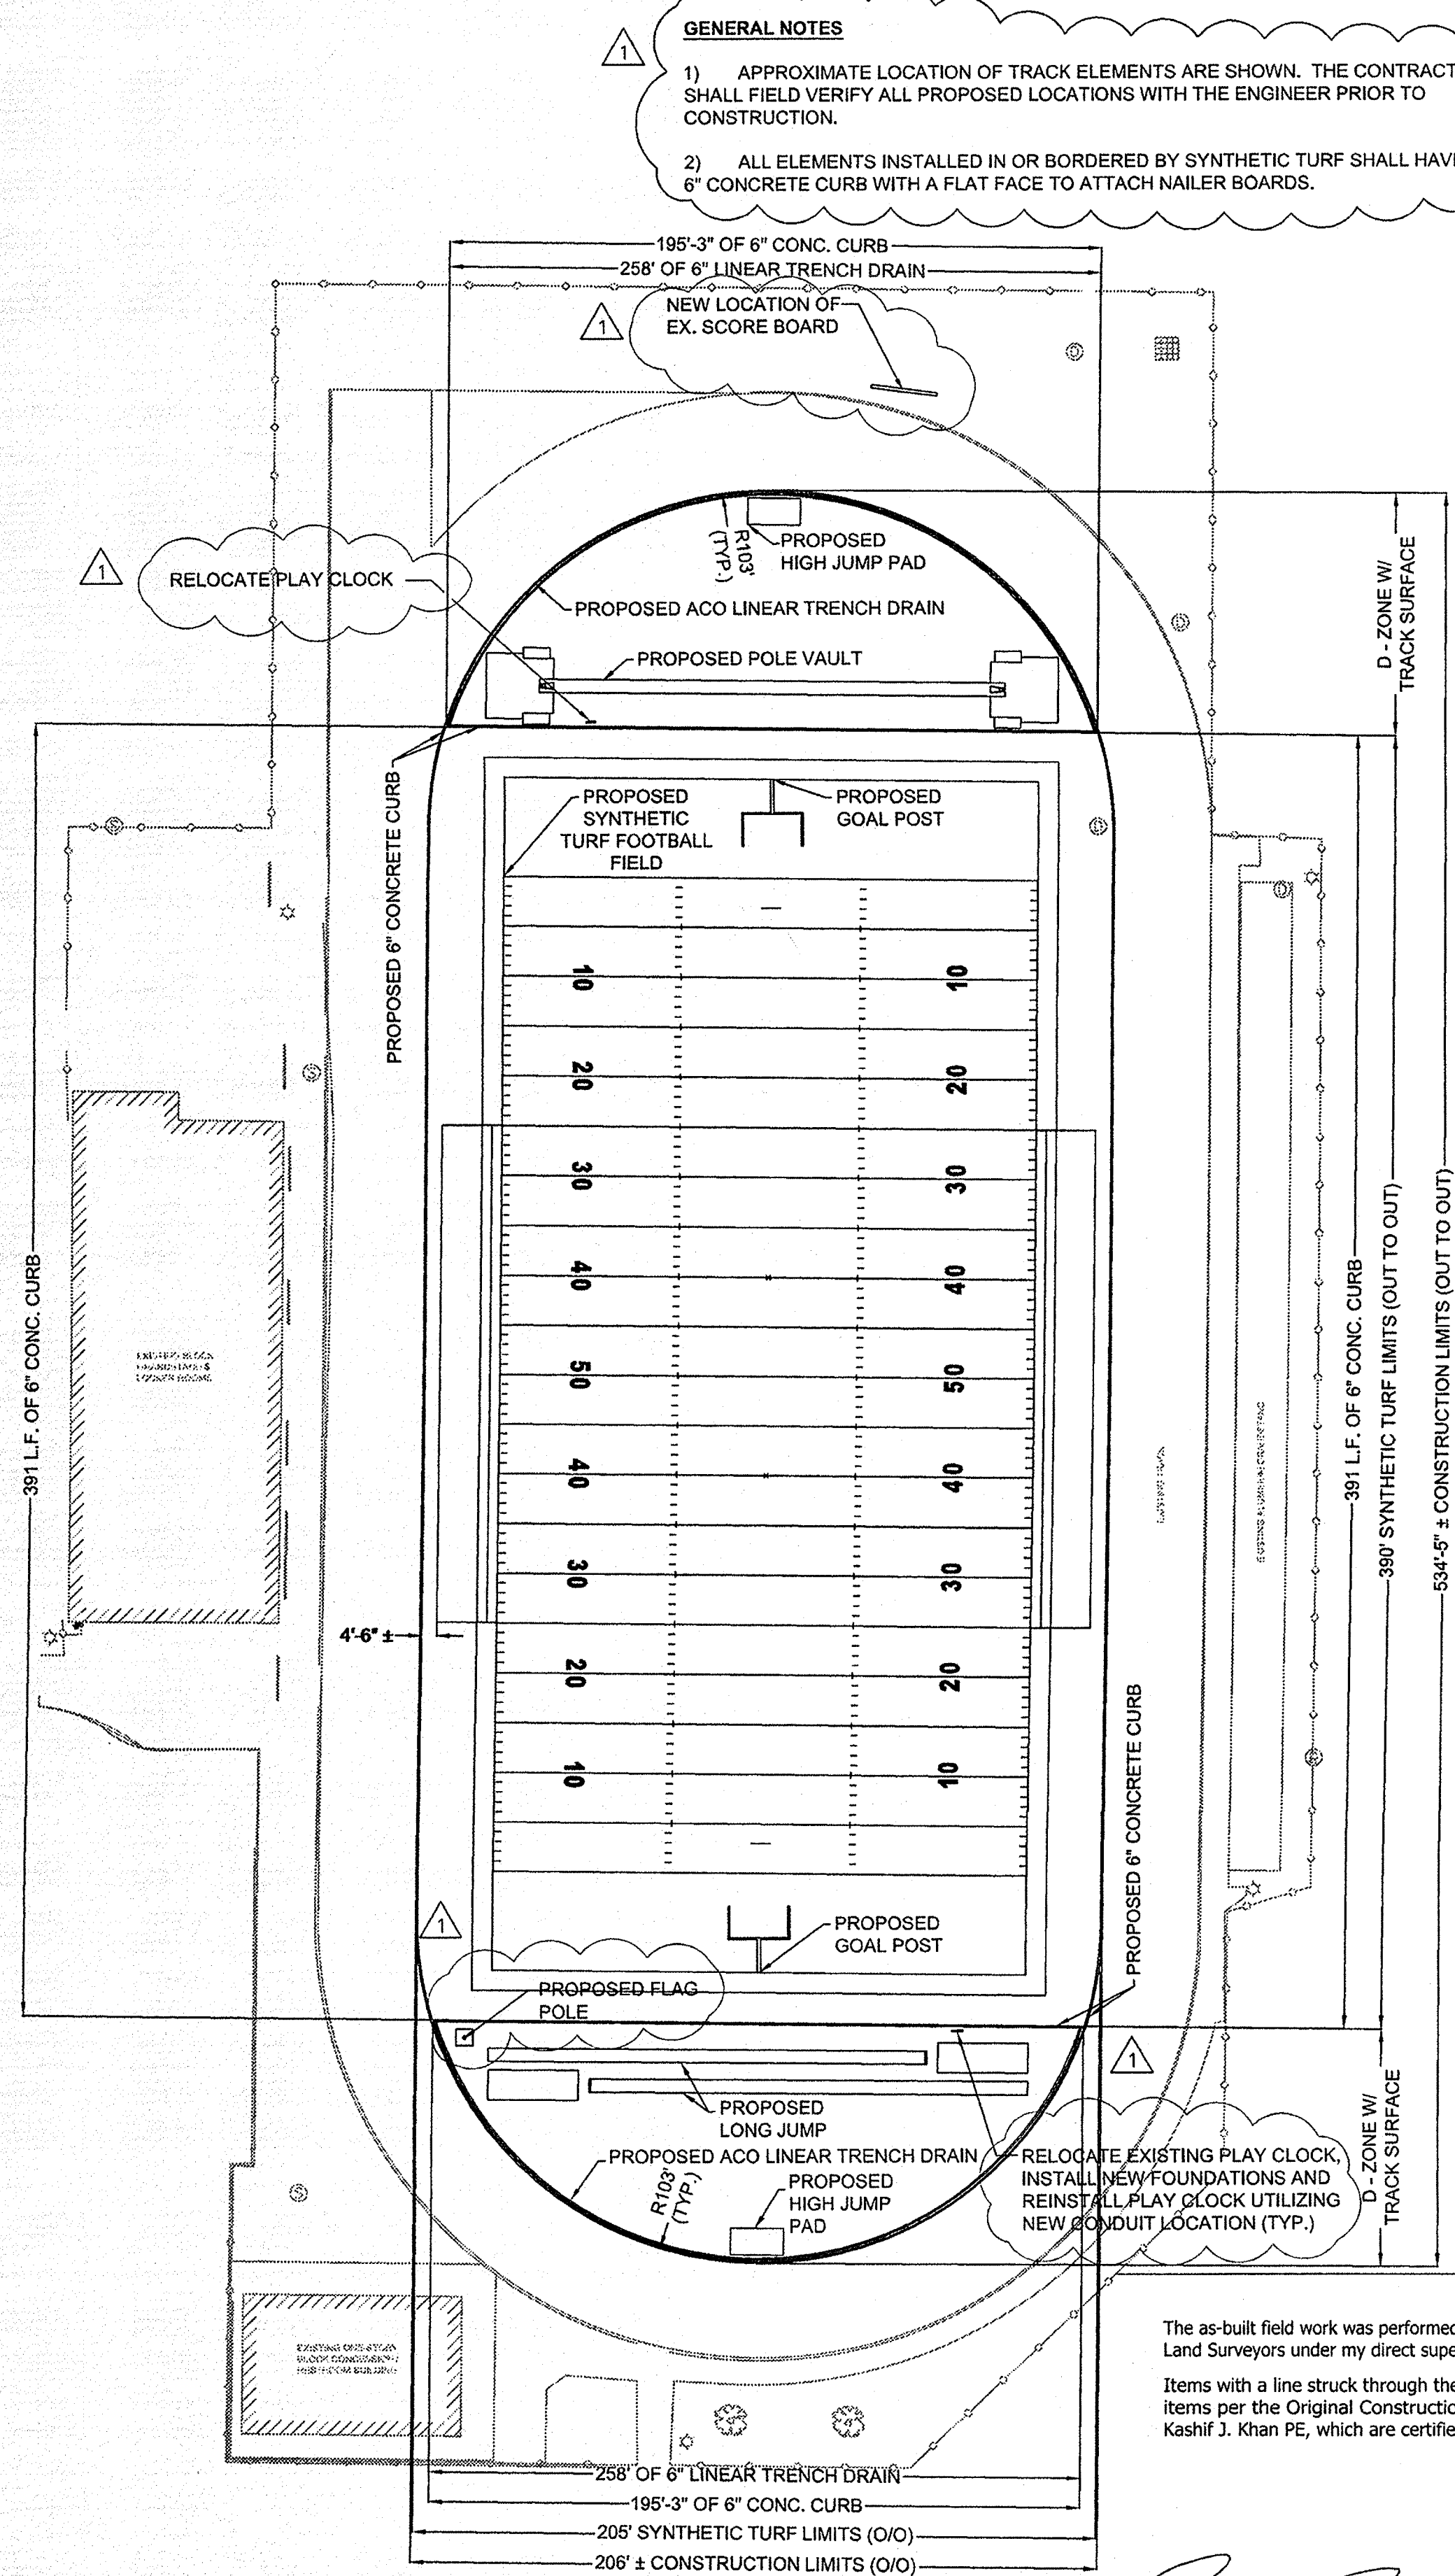


SITE PLAN

The as-built field work was performed by SEA GROUP LLC, Land Surveyors under my direct supervision and direction. Items with a line struck through them are the proposed items per the Original Construction Plans, Signed by Kashif J. Khan PE, which are certified April 25, 2008.

Brian C. Rismiller
Brian C. Rismiller
Registered Land Surveyor
Indiana No. LS20200083
SEA Group, Land Surveyors
494 Grady Dr., Carmel, IN 46032
(317) 844-3333

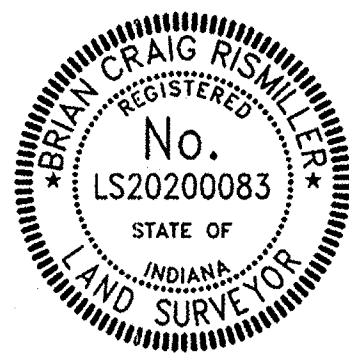


AS-BUILT NOTE:
TOP OF CURB MEASURED @ FACE OF CURB. TRACK & CURB ARE GENERALLY THE SAME.
Rubberized Track Coating Was Applied AFTER AS-BUILT MEASUREMENTS.
ADD 0.10' +/- FOR TOP OF TRACK

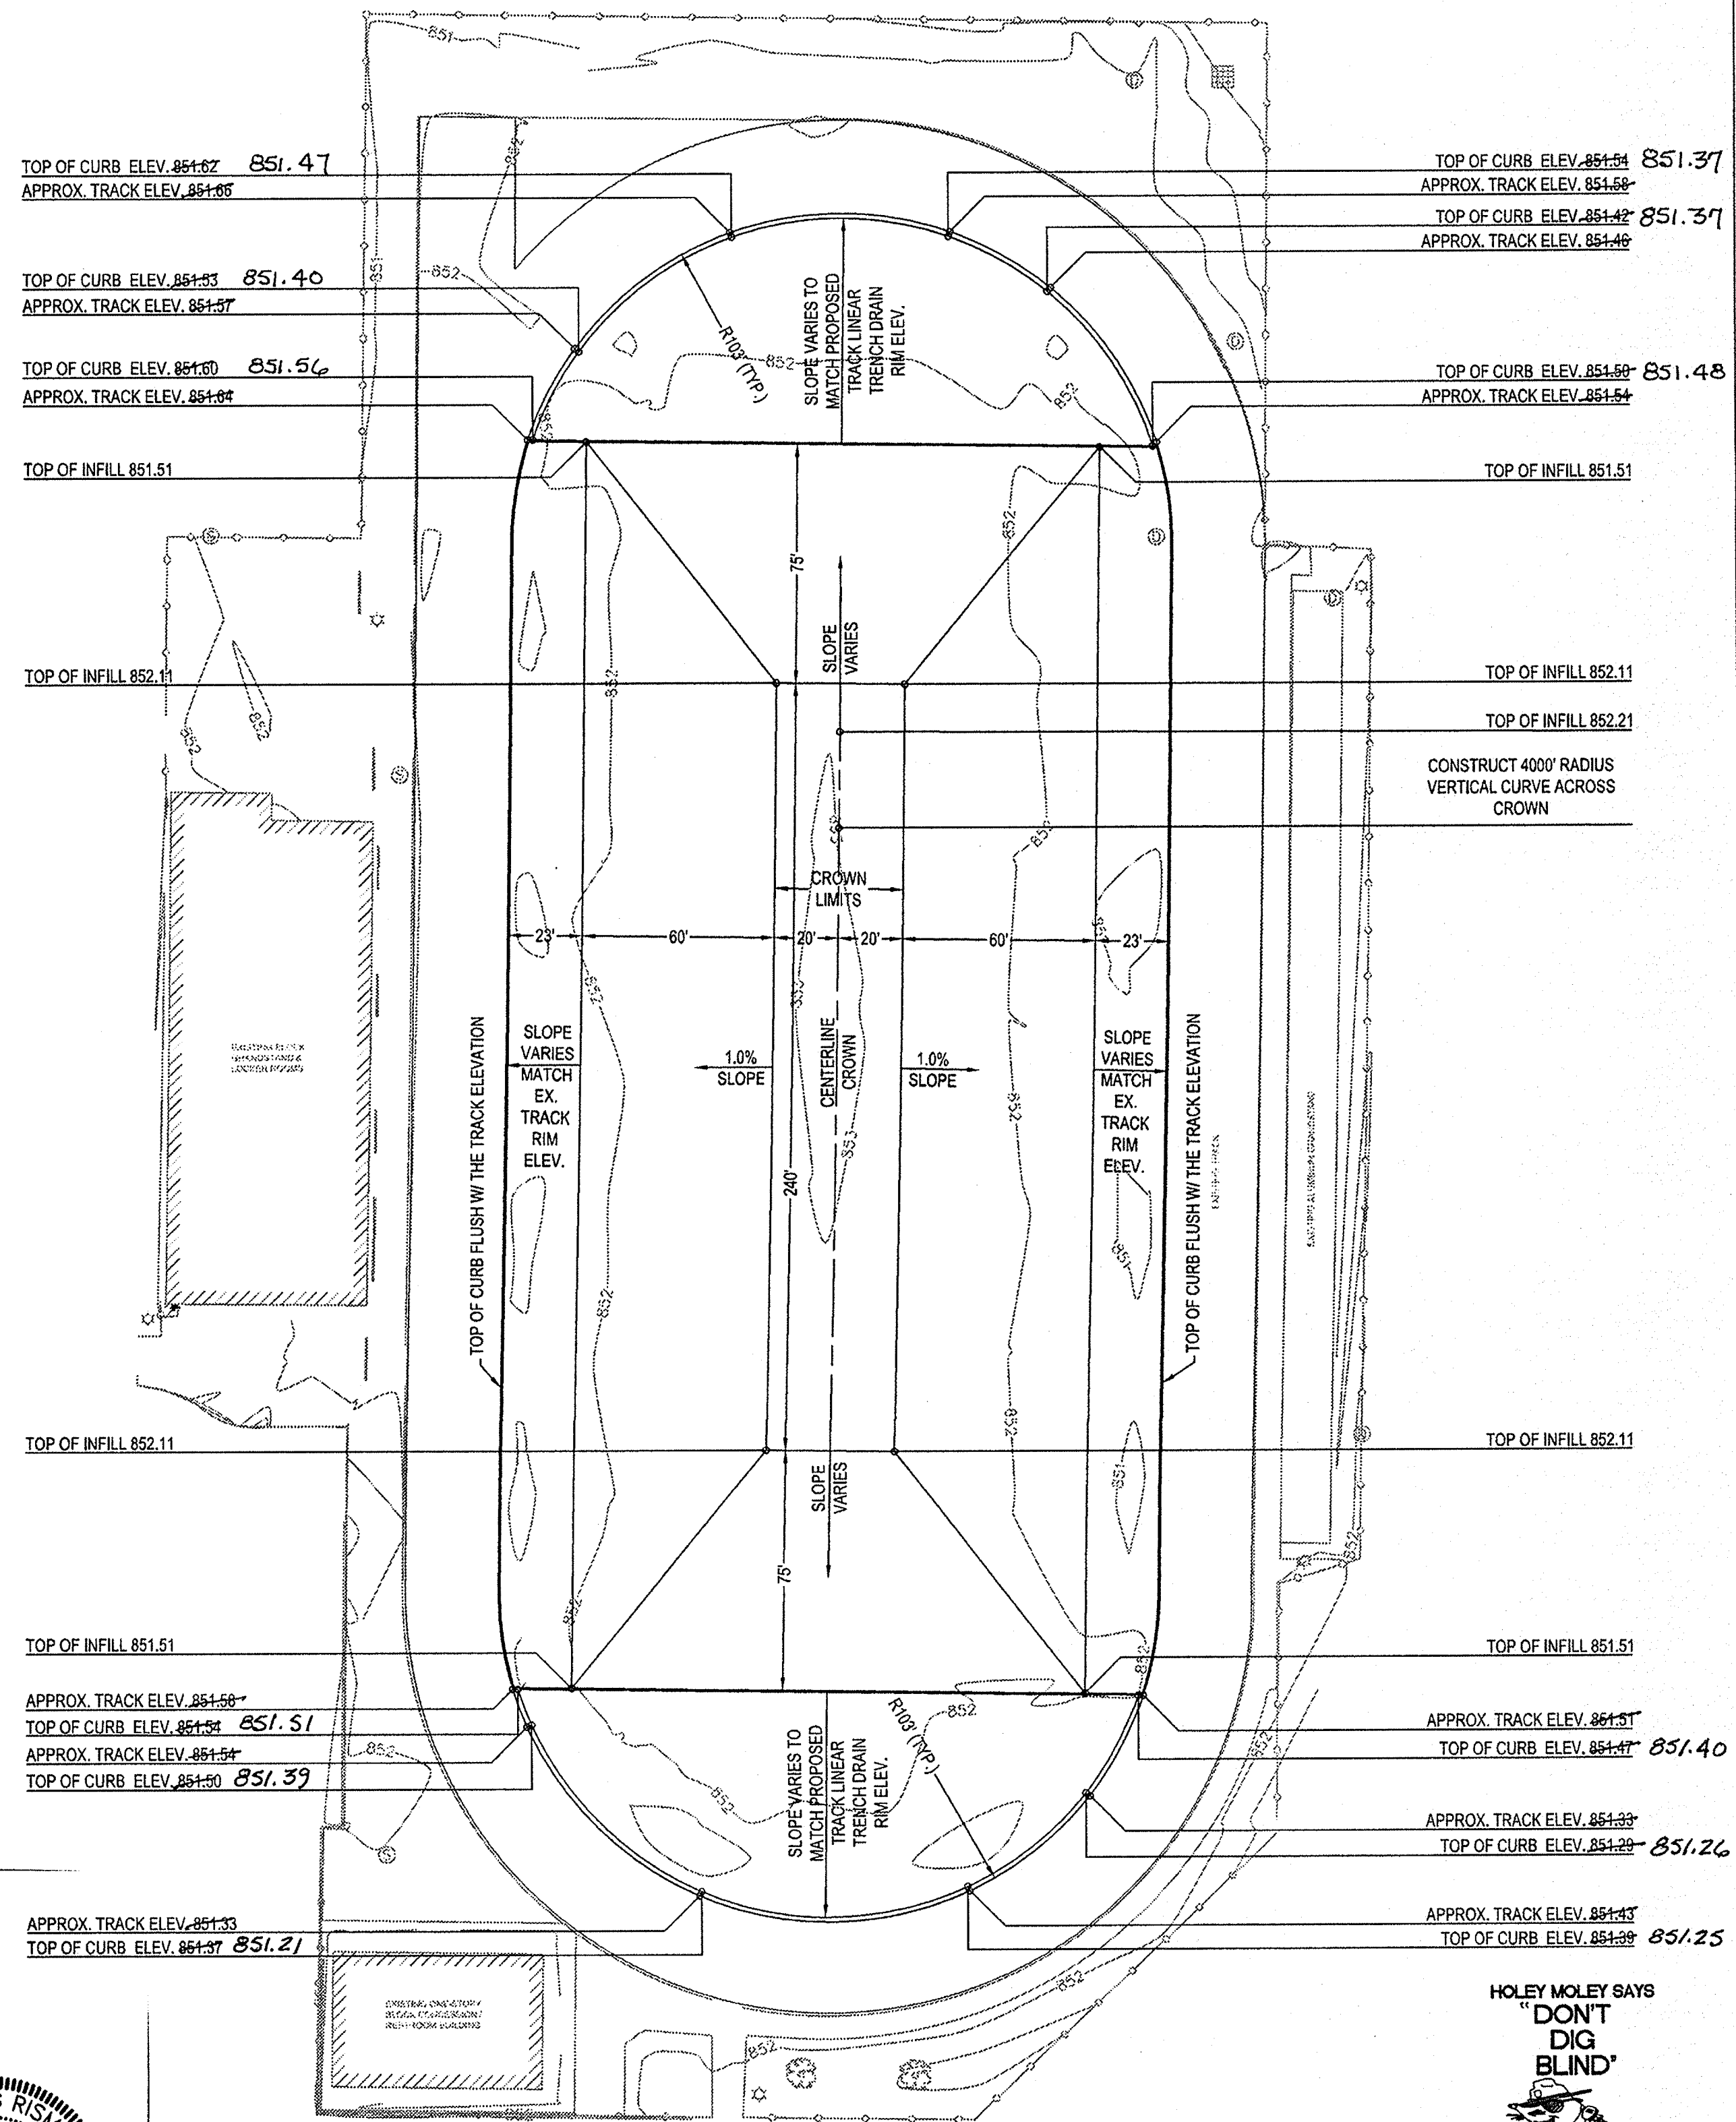

GRADING PLAN

HOLEY MOLEY SAYS "DON'T DIG BLIND"
"IT'S THE LAW"
CALL 1-800-382-5544
CALL TOLL FREE
PER INDIANA STATE LAW 5-19-1995, IT IS AGAINST THE LAW TO EXCAVATE WITHOUT RECORDING THE UNDERGROUND LOCATION SERVICE TWO (2) WORKING DAYS BEFORE COMMENCING WORK.

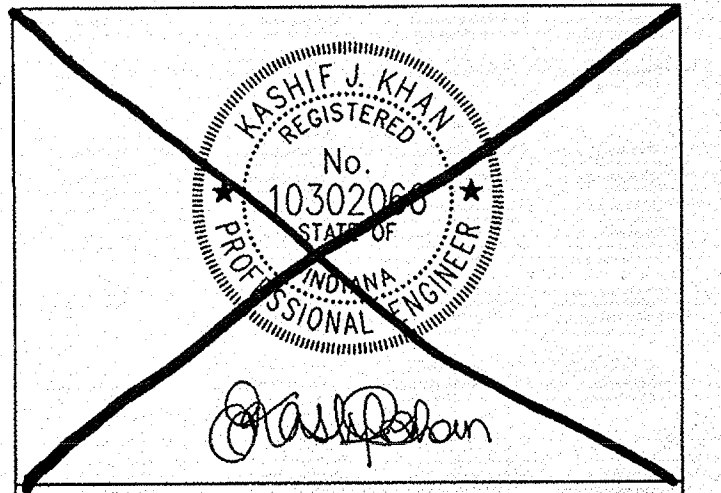


RECORD DRAWING

1	CHANGES TO SITE PLAN AND NOTES	5/9/08
No.	Revision/Issue	Date

INFRASTRUCTURE ENGINEERING, INC.
2601 FORTUNE CIRCLE EAST, SUITE 201C
INDIANAPOLIS, IN 46241
PHONE: 317.243.9800
info@infrastructure-eng.com


METROPOLITAN SCHOOL DISTRICT OF LAWRENCE TOWNSHIP
CONSTRUCTION PLANS
LAWRENCE CENTRAL HIGH SCHOOL
ATHLETIC FIELD IMPROVEMENTS
7300 East 56th Street
Indianapolis, IN 46226

Street Name	
SITE & GRADING PLAN	
Project	Sheet Number
08-2052	
Date	
APRIL 25, 2008	
Scale	
1 INCH = 40 FEET	S-201

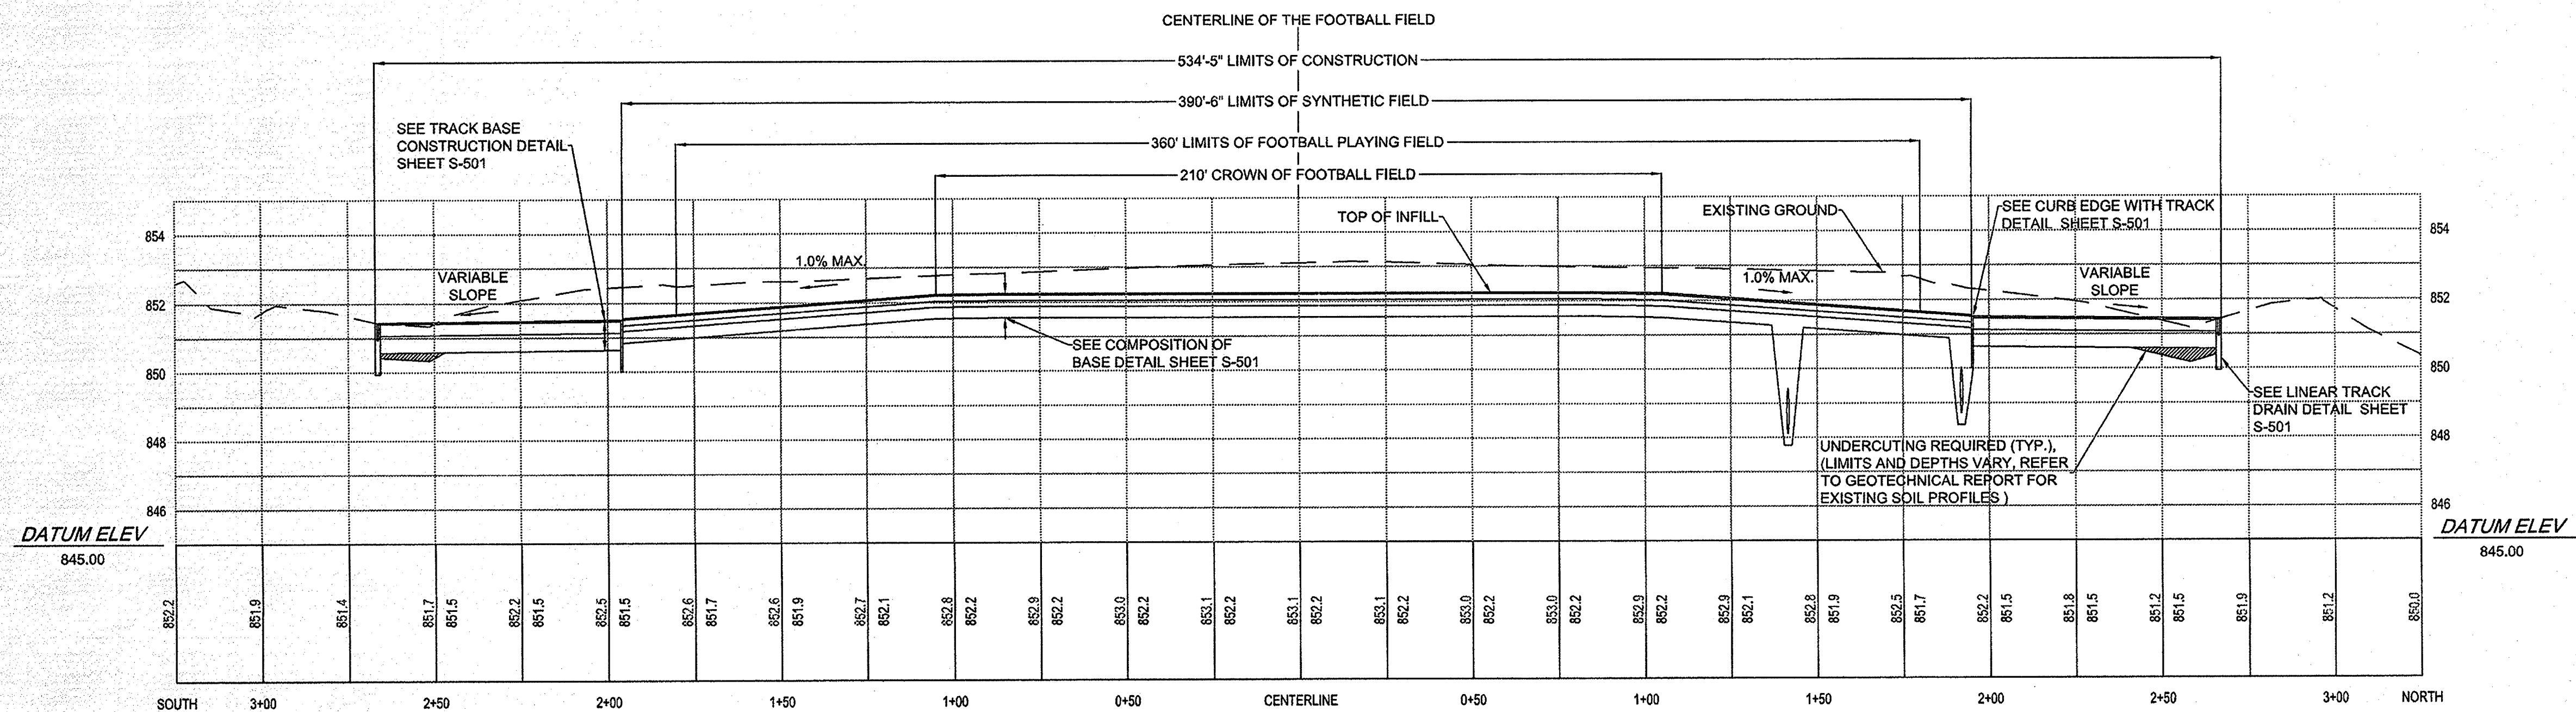


FOOTBALL FIELD PROFILE

SCALE:
VERTICAL: 1" = 10'
HORIZONTAL: 1" = 30'

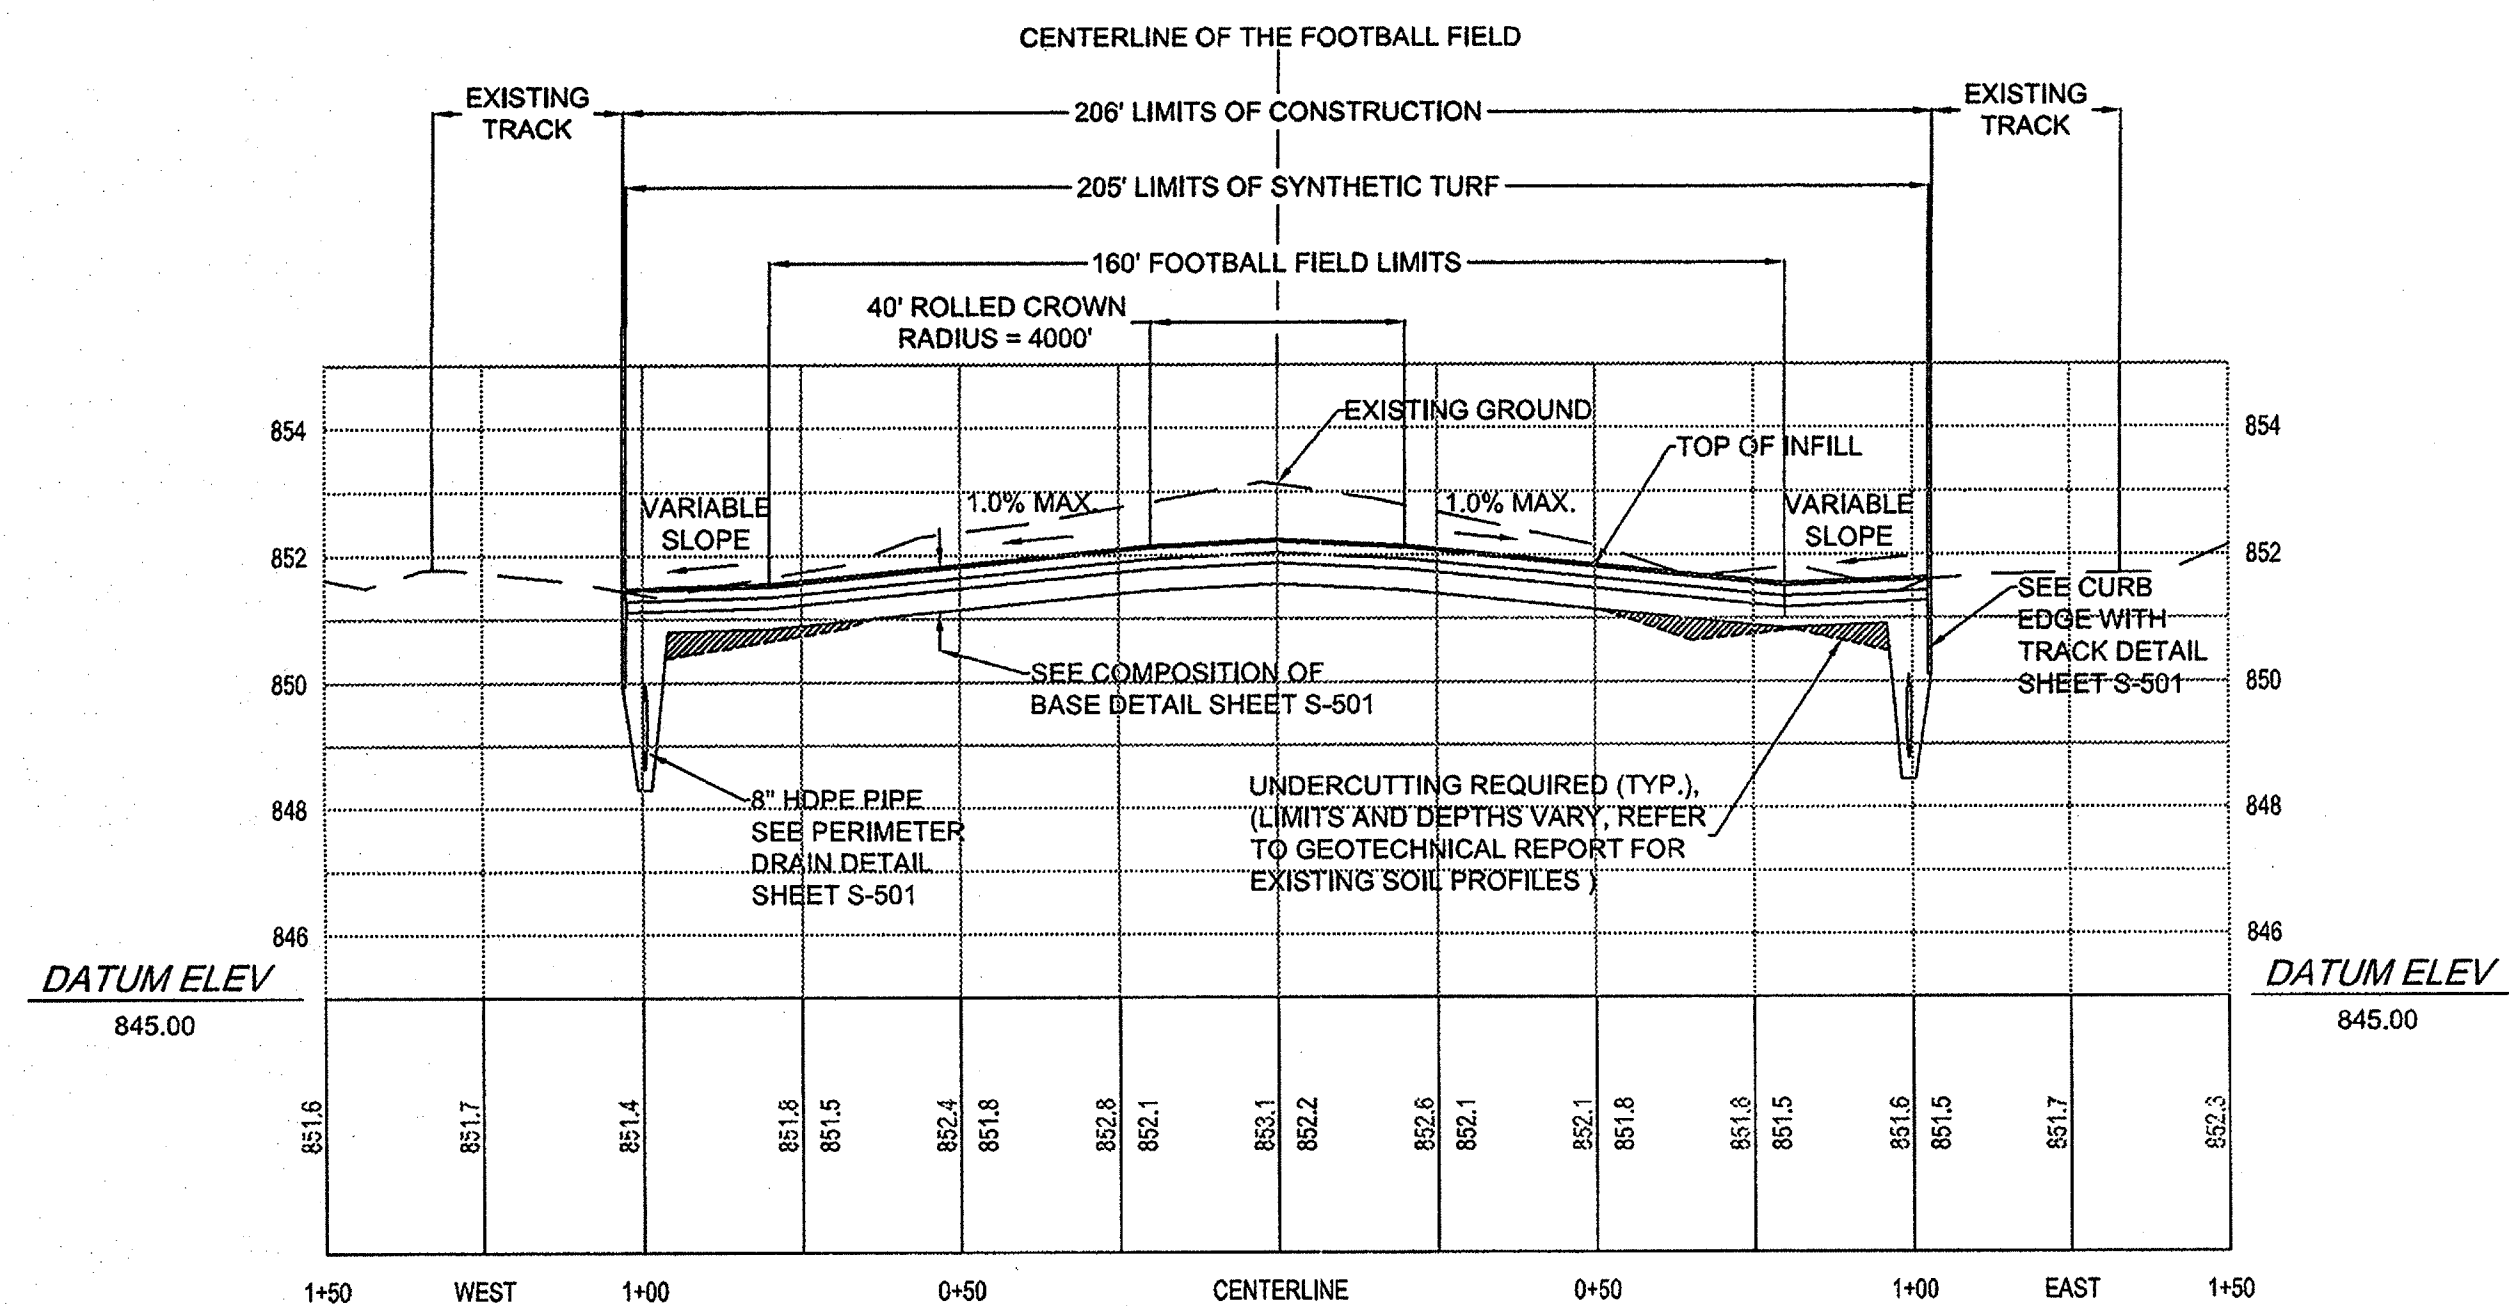

TYPICAL FOOTBALL FIELD CROSS SECTION @ CENTER OF FIELD

SCALE:
VERTICAL: 1" = 10'
HORIZONTAL: 1" = 30'

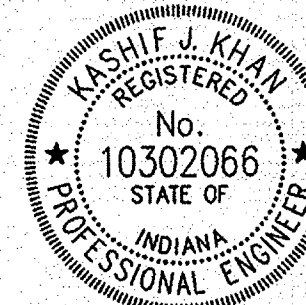

M. Khan

No.	Revision/Issue	Date


INFRASTRUCTURE ENGINEERING, INC.
2601 FORTUNE CIRCLE EAST,
SUITE 201C
INDIANAPOLIS, IN 46241
PHONE: 317.243.9800
info@infrastructure-eng.com

METROPOLITAN SCHOOL DISTRICT OF
LAWRENCE TOWNSHIP

CONSTRUCTION PLANS
LAWRENCE CENTRAL HIGH SCHOOL
ATHLETIC FIELD IMPROVEMENTS

7300 East 56th Street
Indianapolis, IN 46226

PROFILE AND CROSS SECTIONS		
Project	08-2052	Sheet Number
Date	APRIL 25, 2008	S-202
Scale	1 INCH = 30 FEET	

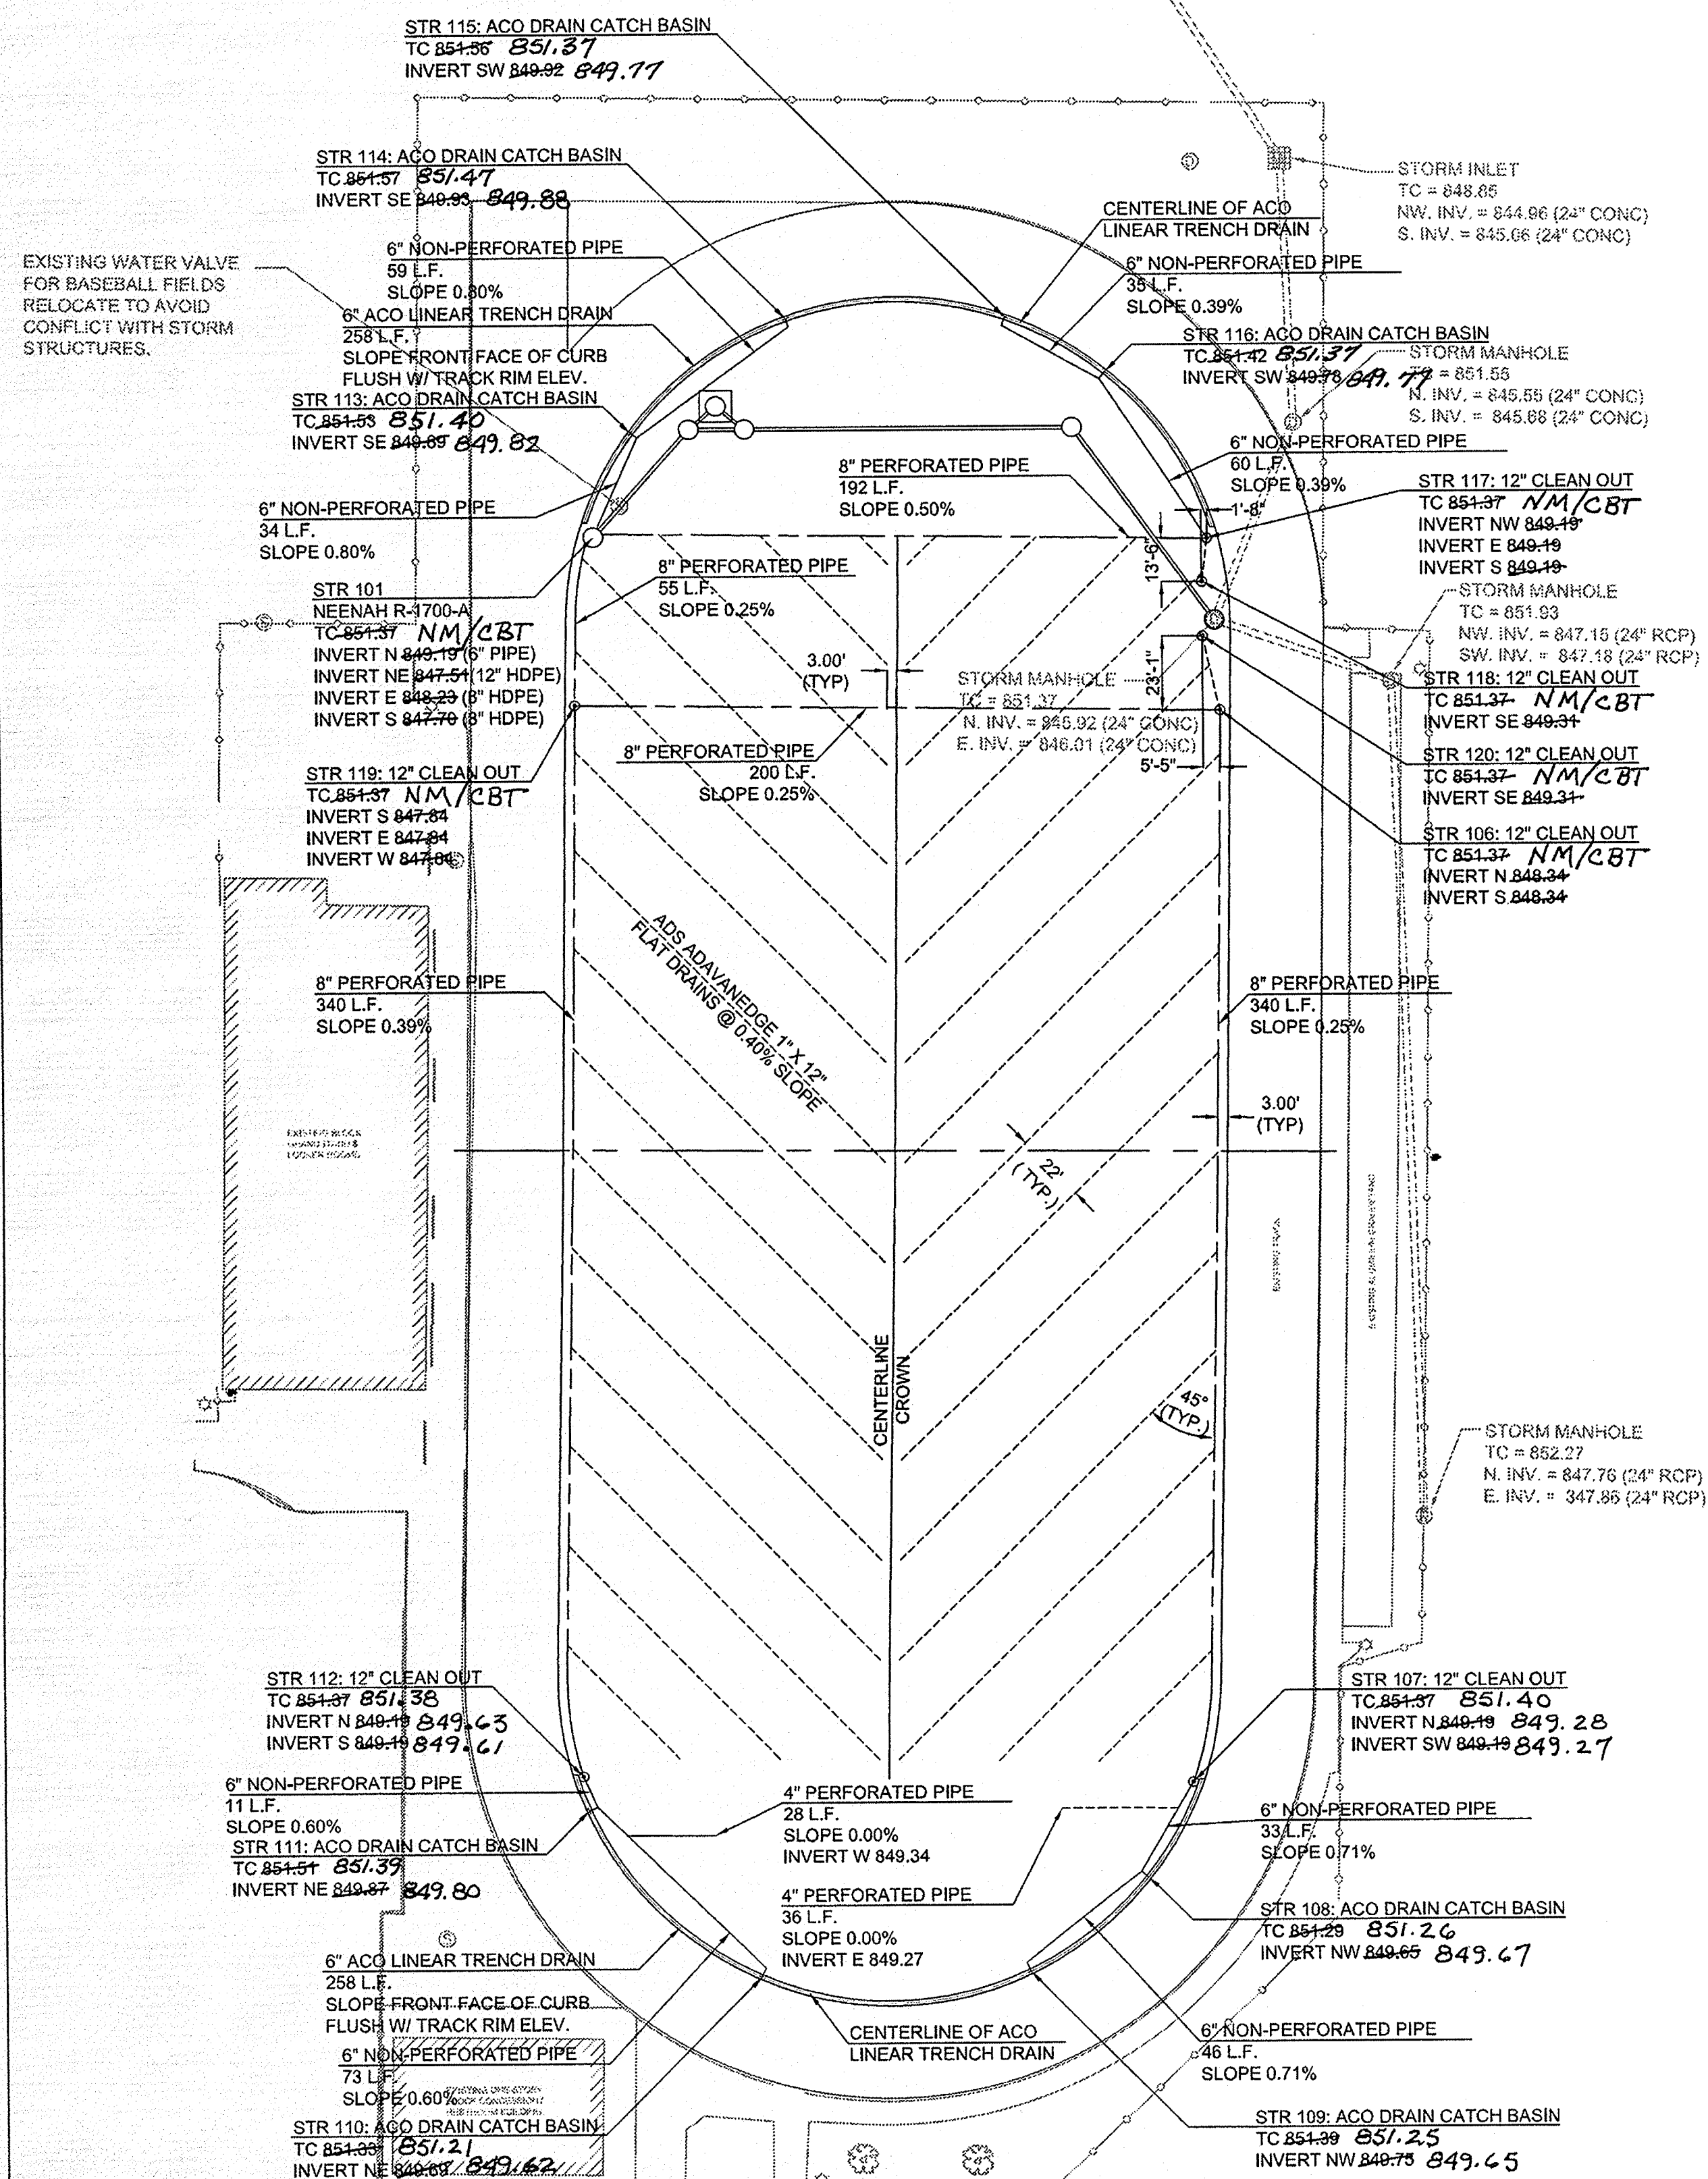

LEGEND
 NM/CBT = NOT MEASURED
 COVERED BY TURF

STORM DRAINAGE PLAN
 SCALE 1 INCH = 40 FEET


The as-built field work was performed by SEA GROUP LLC, Land Surveyors under my direct supervision and direction. Items with a line struck through them are the proposed items per the Original Construction Plans, Signed by Kashif J. Khan PE, which are certified April 25, 2008.

Brian C. Rismiller
 Brian C. Rismiller
 Registered Land Surveyor
 Indiana No. LS20200083
 SEA Group, Land Surveyors
 494 Grady Dr. Carmel, IN 46032
 (317) 844-3333




GENERAL NOTES

- 1) APPROXIMATE LOCATION OF LOW POINTS IN THE D-ZONE ARE SHOWN. THE CONTRACTOR SHALL FIELD VERIFY ALL LOW POINT ALONG THE PROPOSED ACO LINEAR TRENCH DRAIN LOCATIONS AND ADJUST THE LOCATIONS OF THE LINEAR TRENCH CATCH BASINS TO MATCH THE LOW POINTS PRIOR TO THE START OF CONSTRUCTION.
- 2) CONNECT ALL OFFSITE DRAINS IN THE FIELD TO THE NEAREST PROPOSED STORM STRUCTURE.

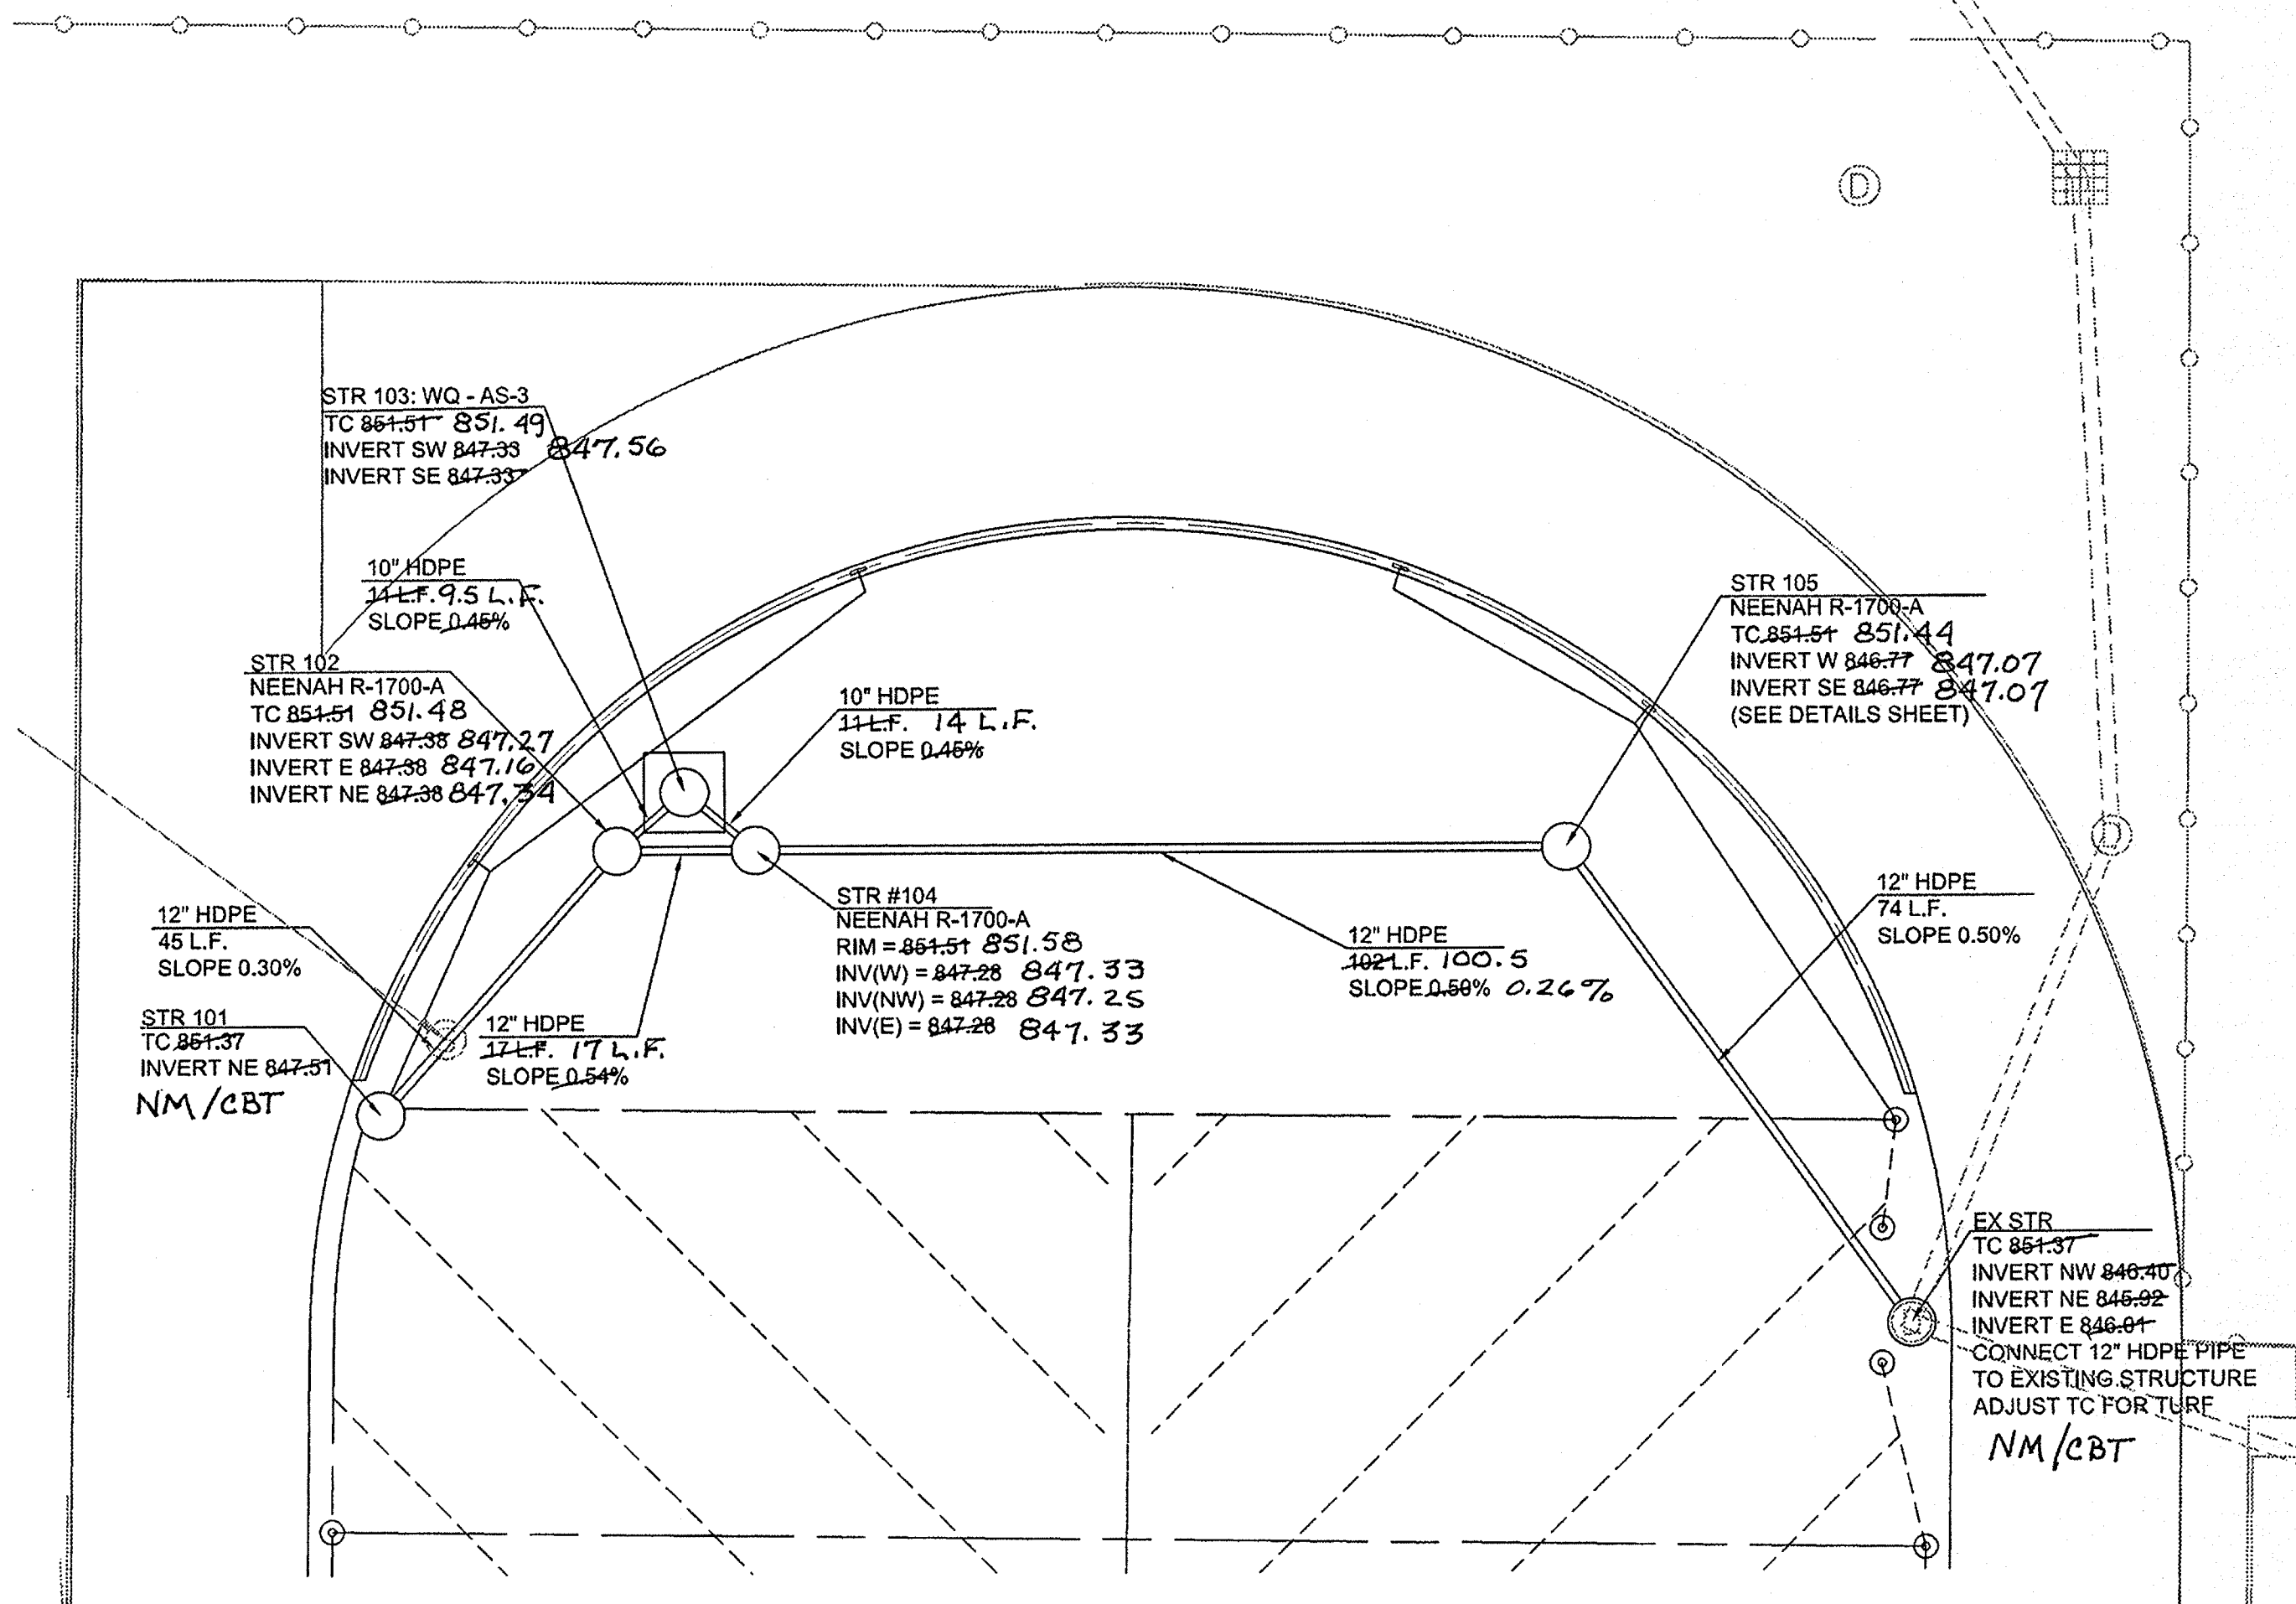

STORMWATER TREATMENT PLAN
 SCALE 1 INCH = 20 FEET

As built Notes:
 (WQ STR AS-3) WATER LEVEL @ INLET HEIGHT
 UNABLE TO MEASURE OUTLET INVERT.

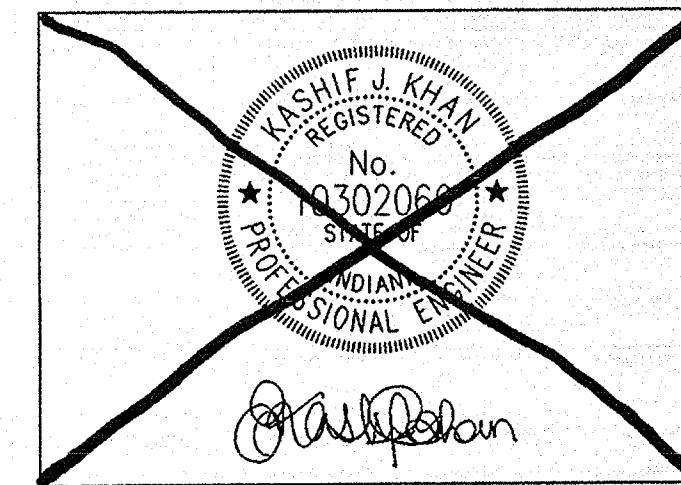

RECORD DRAWING

No.	Revision/Issue	Date

INFRASTRUCTURE ENGINEERING, INC.
 2801 FORTUNE CIRCLE EAST,
 SUITE 201C
 INDIANAPOLIS, IN 46241
 PHONE: 317.243.9800
 info@infrastructure-eng.com


METROPOLITAN SCHOOL DISTRICT OF
 LAWRENCE TOWNSHIP
 CONSTRUCTION PLANS
 LAWRENCE CENTRAL HIGH SCHOOL
 ATHLETIC FIELD IMPROVEMENTS
 7300 East 56th Street
 Indianapolis, IN 46226

Sheet Name	
STORM DRAINAGE PLAN	
Project	Sheet Number
08-2052	
Date	
APRIL 25, 2008	
Scale	
AS NOTED	S-301

1

GENERAL NOTES

- 1) APPROXIMATE LOCATION OF UTILITIES ARE SHOWN. THE CONTRACTOR SHALL FIELD VERIFY ALL PROPOSED LOCATIONS WITH THE ENGINEER PRIOR TO CONSTRUCTION.
- 2) THE CONTRACTOR SHALL INSTALL ALL PROPOSED AND EXISTING ELECTRICAL EQUIPMENT IN WORKING ORDER PER MANUFACTURERS RECOMMENDATIONS.
- 3) THE CONTRACTOR SHALL INSTALL AND CONNECT ALL CABLING FOR EXISTING AND PROPOSED ELECTRICAL EQUIPMENT PER MANUFACTURERS RECOMMENDATIONS.
- 4) IN CASE OF A CONFLICT BETWEEN PROPOSED UTILITIES THE LOCATION OF WATER VALVES AND JUNCTION BOXES TAKE PRECEDENCE OVER THE LOCATION OF THE ADS ADVANEDGE DRAINS.

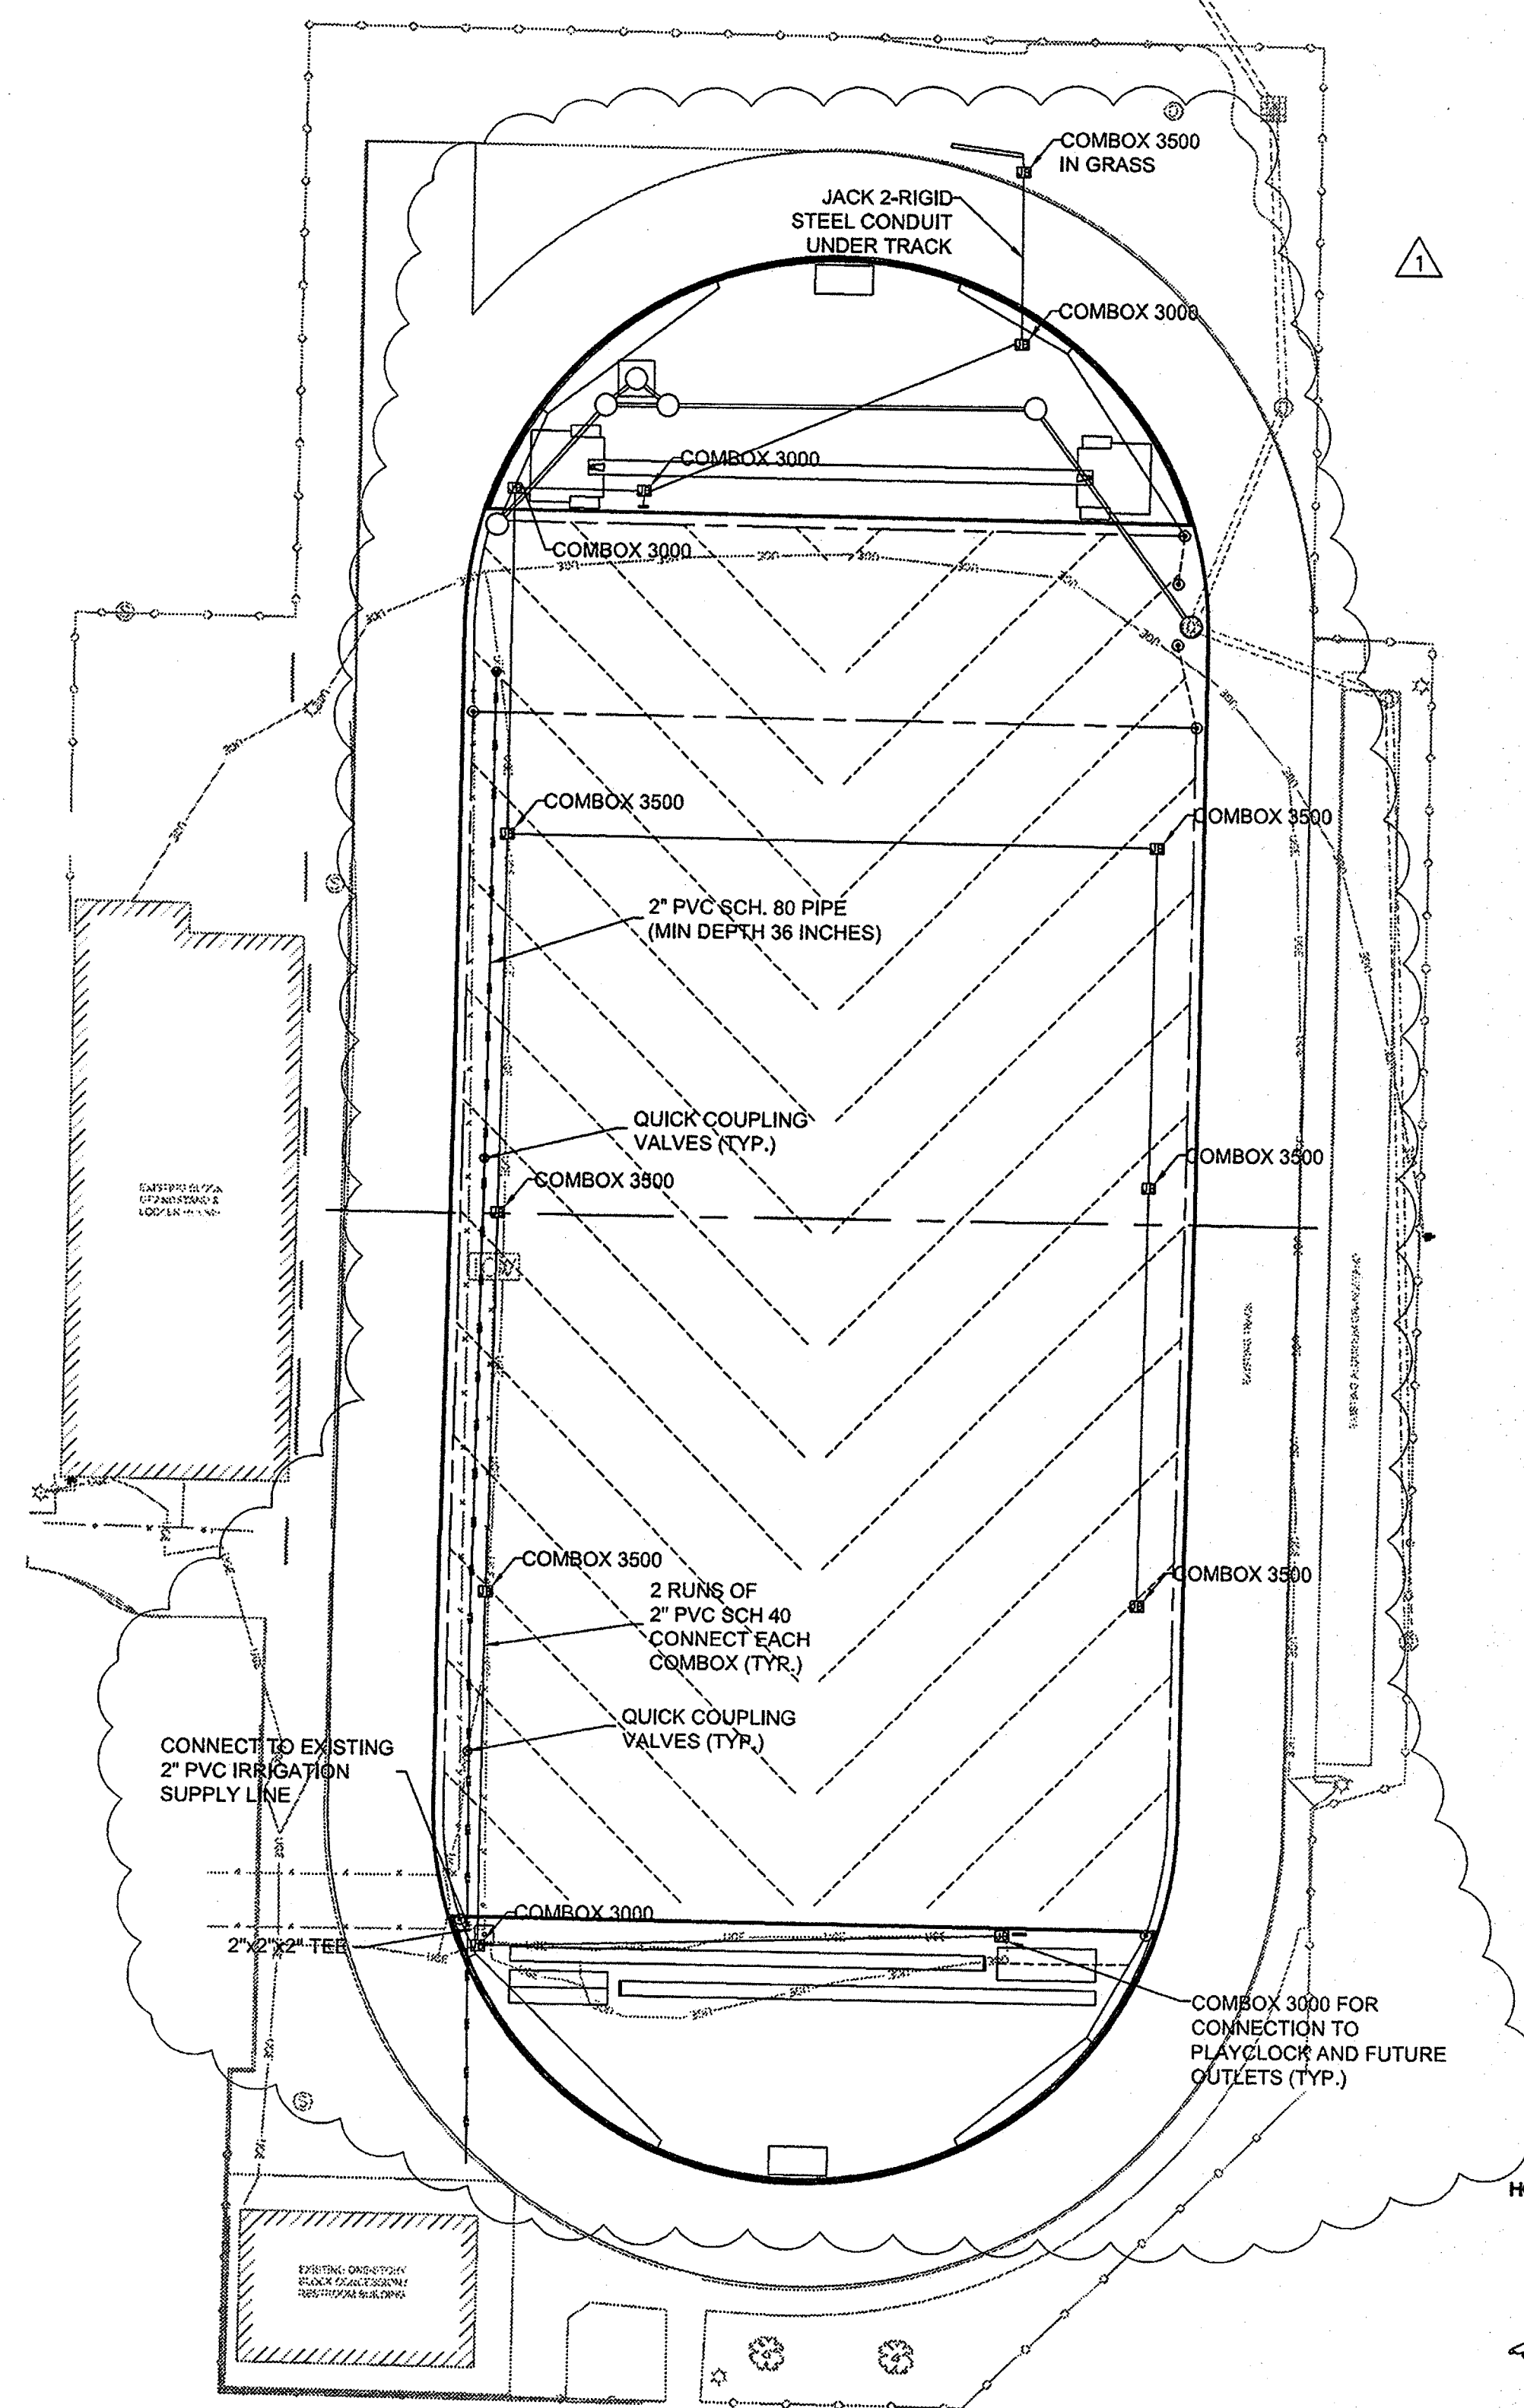

UTILITY PLAN



Kasim J. Khan

1	CHANGES TO UTILITY LAYOUT AND NOTES	5/9/08
No.	Revision/Issue	Date

INFRASTRUCTURE ENGINEERING, INC.
2601 FORTUNE CIRCLE EAST,
SUITE 201C
INDIANAPOLIS, IN 46241
PHONE: 317.243.9800
info@infrastructure-eng.com

METROPOLITAN SCHOOL DISTRICT OF
LAWRENCE TOWNSHIP


CONSTRUCTION PLANS
LAWRENCE CENTRAL HIGH SCHOOL
ATHLETIC FIELD IMPROVEMENTS

7300 East 56th Street
Indianapolis, IN 46226

UTILITY PLAN		
Project	08-2052	Sheet Number
Date	APRIL 25, 2008	
Scale	1 INCH = 40'	S-302

GENERAL NOTES

- 1) TEMPORARY SEEDING REQUIRED FOR ALL DISTURBED AREAS
2) REFER TO EROSION CONTROL DETAIL SHEET FOR ADDITIONAL INFORMATION

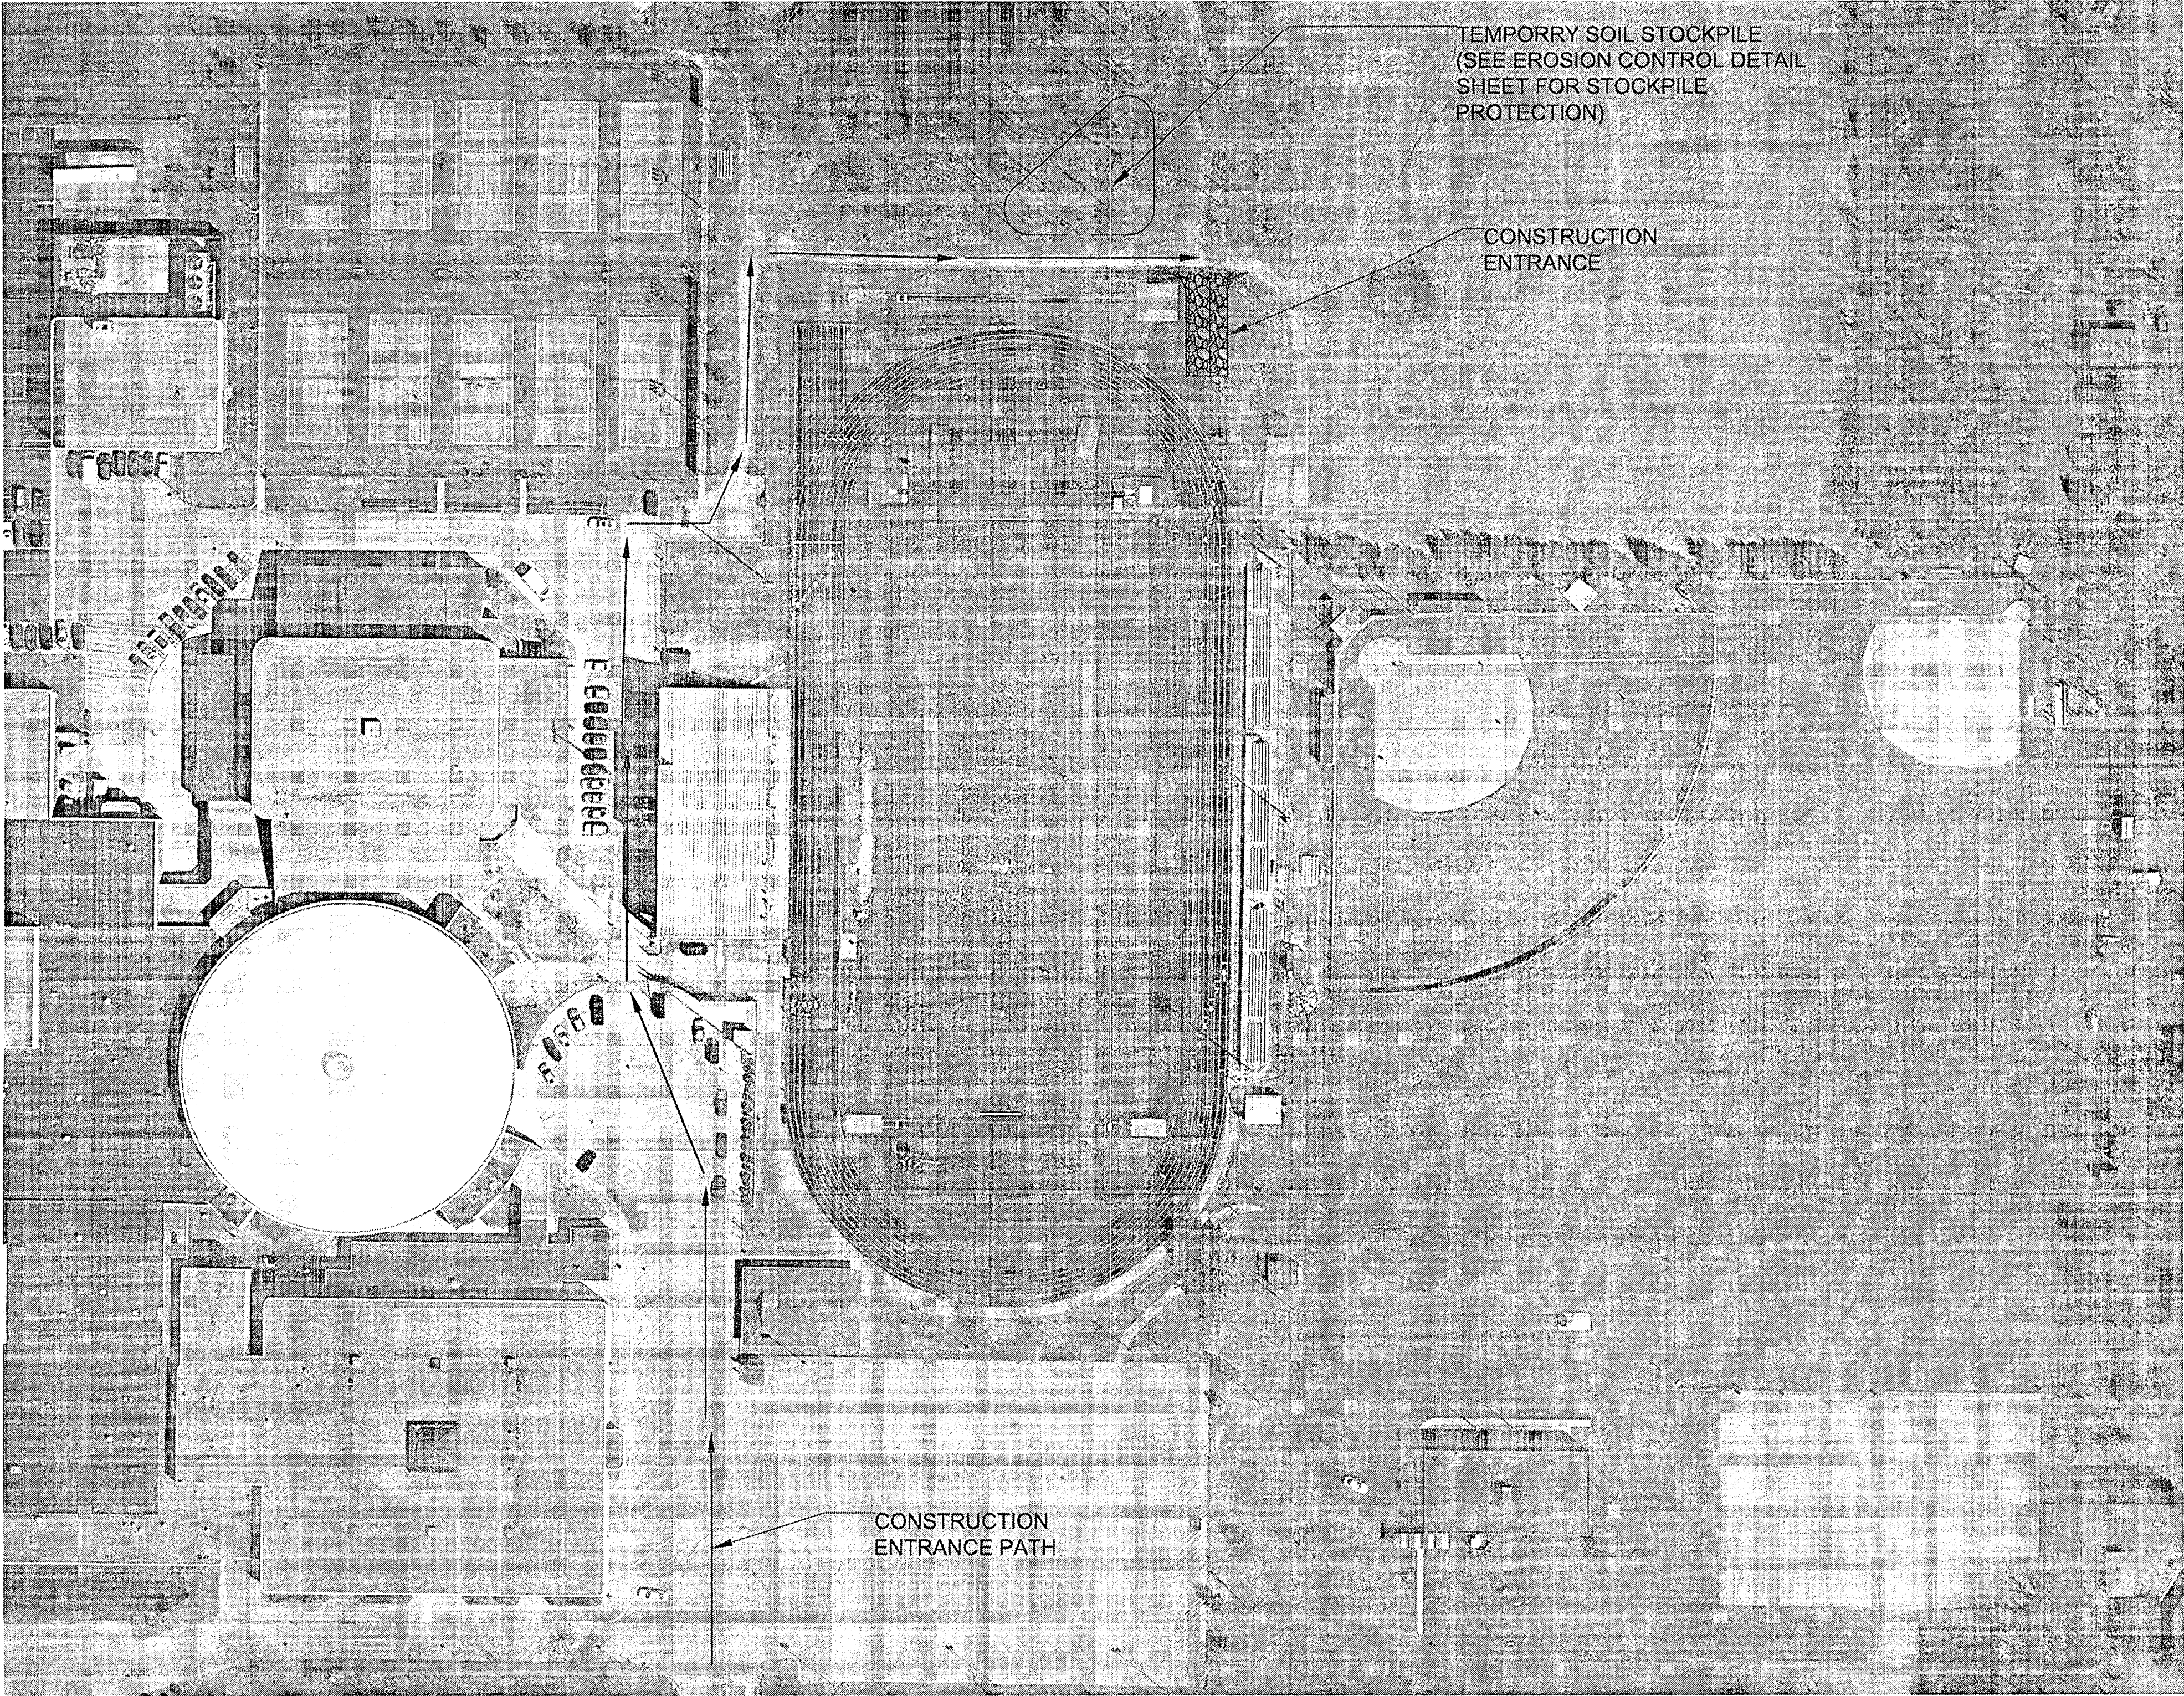


⦿ EROSION CONTROL & CONSTRUCTION ACCESS PLAN



Kashif J. Khan

No.	Revision/Issue	Date

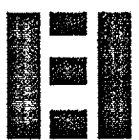
INFRASTRUCTURE ENGINEERING, INC.
2601 FORTUNE CIRCLE EAST,
SUITE 201C
INDIANAPOLIS, IN 46241
PHONE: 317.243.9800
info@infrastructure-eng.com

METROPOLITAN SCHOOL DISTRICT OF
LAWRENCE TOWNSHIP

CONSTRUCTION PLANS
LAWRENCE CENTRAL HIGH SCHOOL
ATHLETIC FIELD IMPROVEMENTS

7300 East 56th Street
Indianapolis, IN 46226

Sheet Name: EROSION CONTROL & CONSTRUCTION ACCESS PLAN	
Project: 08-2052	Sheet Number:
Date: APRIL 25, 2008	
Scale: NTS	S-401

EROSION CONTROL NOTES

DURING ALL PHASES OF CONSTRUCTION THE SITE EXCAVATION CONTRACTOR AND ALL SUB-CONTRACTORS SHALL EXERCISE MEASURES TO PREVENT THE EROSION OF SOILS DUE TO THE ACTION OF WATER AND WIND. ALL EROSION AND SEDIMENT CONTROL MEASURES SHALL BE IMPLEMENTED PRIOR TO EARTH MOVING ACTIVITIES.

LAND ALTERATIONS THAT STRIP THE LAND OF VEGETATION, INCLUDING REGRADING, SHALL BE DONE IN A WAY THAT WILL MINIMIZE EROSION. WHENEVER FEASIBLE, NATURAL VEGETATION SHALL BE RETAINED, PROTECTED AND SUPPLEMENTED.

THE DURATION OF TIME THAT AN AREA REMAINS EXPOSED SHALL BE KEPT TO A PRACTICAL MINIMUM. THE AREA SHALL BE STABILIZED AS QUICKLY AS PRACTICAL.

TEMPORARY VEGETATION OR MULCHING SHALL BE USED TO PROTECT EXPOSED AREAS DURING DEVELOPMENT. PERMANENT AND FINAL VEGETATION OR STRUCTURAL EROSION CONTROL DEVICES SHALL BE INSTALLED AS SOON AS PRACTICAL.

SEDIMENT IN RUN-OFF WATER SHALL BE TRAPPED BY THE USE OF SUCH METHODS AS SILT FENCES UNTIL THE DISTURBED AREA IS STABILIZED.

THE SITE CONTRACTOR SHALL PERIODICALLY INSPECT TRAPPING DEVICES DURING DRY PERIODS AND AFTER EACH RAINFALL EVENT. TRAPPING DEVICES SHALL BE REPLACED IF DETERMINED TO BE INCAPABLE OF PERFORMING INTENDED FUNCTION.

CONTRACTOR SHALL MAINTAIN EROSION CONTROL MEASURES AS REQUIRED DURING CONSTRUCTION, UNTIL A VEGETATIVE COVER HAS ESTABLISHED SUFFICIENTLY TO STABILIZE THE SOILS AND PREVENT EROSION.

THE CONTRACTOR SHALL HAVE AVAILABLE ON THE CONSTRUCTION SITE A WATER SOURCE CAPABLE OF APPLYING WATER TO DRY EXPOSED SOIL IN ORDER TO PREVENT WIND EROSION. THE APPLICATION RATE AND MANNER SHALL BE SUCH THAT SOIL MOISTURE IS ATTAINED AND NO SURFACE RUN-OFF IS CREATED.

ALL DISTURBED AREAS TO BE SEEDED.

ALL EROSION CONTROL MEASURES SHALL COMPLY WITH RULE 5.

ALL EROSION AND SEDIMENT CONTROL WORK SHALL CONFORM TO THE STANDARDS, SPECIFICATIONS AND PROCEDURES OF THE CITY, COUNTY, OR OTHER GOVERNING AGENCIES, WHICHEVER HAS JURISDICTION.

SOIL EROSION CONTROL DEVICES AND PRACTICES WILL BE ESTABLISHED IMMEDIATELY BEFORE ANY CLEARING, GRADING, EXCAVATING, FILLING OR OTHERWISE DISTURBING OF NATURAL TERRAIN. THE CONTRACTOR SHALL PRESERVE THE NATURAL VEGETATION AS MUCH AS POSSIBLE.

ALL EROSION AND SEDIMENT CONTROL DEVICES SHALL REMAIN IN PLACE DURING THE ENTIRE CONSTRUCTION PHASE. ONLY THOSE CONTROLS AND DEVICES THAT ARE TEMPORARY IN NATURE SHALL BE MOVED OR MODIFIED TO ALLOW PROGRESS OF CONSTRUCTION. DAILY INSPECTIONS MUST BE MADE BY THE CONTRACTOR FOR EFFECTIVENESS OF THE EROSION AND SEDIMENT CONTROL DEVICES. NECESSARY REPAIRS SHALL BE MADE WITHOUT DELAY. THE CONTRACTOR SHALL BE RESPONSIBLE FOR THE CARE, MAINTENANCE, REPAIR AND RECONSTRUCTION OF ALL DEVICES, CONTROLS AND ERODED AREAS. IF THE CONTRACT IS GIVEN TO THE EXCAVATING CONTRACTOR OR A SUBCONTRACTOR AND THEY FAIL TO CARE, AND REPAIR ALL DAMAGES TO EROSION CONTROL DEVICES THEN THE GENERAL CONTRACTOR WILL BE RESPONSIBLE FOR THIS WORK AND ANY DAMAGE THAT MAY HAVE OCCURRED.

FINAL OR TEMPORARY SEEDING AND OR SODDING MUST BE DONE IMMEDIATELY AS DIRECTED BY THE LANDSCAPE PLAN, EROSION CONTROL PLAN AND OR GRADING/DRAINAGE PLAN.

STRAW BALES, SILT FENCING AND OR GRAVEL PROTECTION SHALL BE USED AS INDICATED ON PLANS. IF LOCAL ORDINANCES DICTATE ALTERNATE EROSION CONTROL DEVICES AND DETAILS IT IS THE RESPONSIBILITY OF THE CONTRACTOR TO USE THE REQUIRED DEVICES.

ALL MUD, DIRT OR GRAVEL SPILLED, TRACKED OR DUMPED ON PUBLIC OR PRIVATE ROADS, STREETS OR DRIVEWAYS MUST BE REMOVED QUICKLY AND PROMPTLY BY THE CONTRACTOR.


IMMEDIATELY AFTER SEEDING, MULCH ALL SEEDED AREAS WITH UNWEATHERED STRAW SPREAD UNIFORMLY AT THE RATE OF TWO TONS PER ACRE OR 100 POUNDS PER 1,000 SQUARE FEET. THIS MULCH SHOULD BE ANCHORED WITH A DISC-TYPE ANCHORING TOOL AND OR APPROVED TACKIFIER. IF ALLOWED, A WOOD CELLULOSE FIBER MULCH (HYDROMULCH) AND APPROVED TACKIFIER MAY BE USED IN LIEU OF STRAW MULCH. ALL METHODS MUST MEET ALL THE LOCAL OR CITY REQUIREMENTS.

PIPE LENGTHS INDICATED ARE FOR HYDRAULIC PURPOSES ONLY AND THE CONTRACTOR SHALL BE RESPONSIBLE FOR ACTUAL LENGTHS REQUIRED TO COMPLETE THE INSTALLATION AS SHOWN.

ALL EXCAVATED AREAS TO BE SEEDED OR SODDED AFTER FINAL GRADING UNLESS OTHERWISE NOTED. SEE LANDSCAPE PLAN AND OR EROSION CONTROL PLAN FOR DIRECTION AND VERIFICATION.

EROSION CONTROL CONSTRUCTION SEQUENCE

1. INSTALL SILT FENCE
2. INSTALL CONSTRUCTION DRIVES.
3. INSTALL INLET PROTECTION FOR EXISTING INLETS AND PIPES.
4. COMMENCE GRADING TO ESTABLISH DETENTION AREAS.
5. INSTALL INLET PROTECTION FOR NEW INLETS.
6. PLACE EROSION CONTROL BLANKETS AS REQUIRED.
7. PLACE SOD AT THE BOTTOM OF SWALES & SIDE DITCHES.
8. BEGIN HYDRO-SEEDING / SEEDING
9. UPON REMOVING THE TEMPORARY EROSION CONTROL MEASURES, SEED DISTURBED AREAS AS REQUIRED.

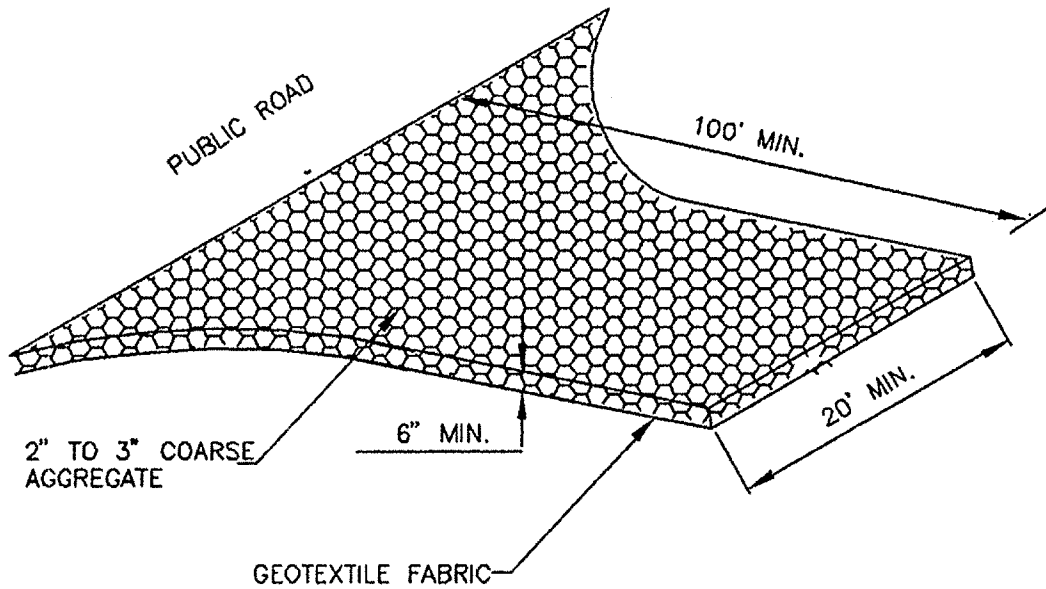

REQUIREMENTS:


1. MATERIAL SHALL BE 2" TO 3" WASHED STONE (INDOT CA NO. 2) OVER A STABLE FOUNDATION.
2. THICKNESS SHALL BE A MINIMUM OF 6 INCHES.
3. THE WIDTH SHALL BE EITHER A 20 FEET MINIMUM OR FULL WIDTH OF THE ENTRANCE/EXIT ROADWAY, WHICHEVER IS GREATER
4. THE LENGTH SHALL BE 100 FEET.
5. MINIMUM GEOTEXTILE FABRIC UNDERLINER MAY BE USED UNDER WET CONDITIONS OR WITH SOILS WITH A HIGH SEASONAL WATER TABLE.

INSTALLATION:

1. AVOID LOCATING ON A STEEP SLOPE OR AT CURVES IN PUBLIC ROADS.
2. REMOVE ALL VEGETATION AND OTHER OBJECTIONABLE MATERIAL FROM THE FOUNDATION AREA, GRADE AND CROWN FOR POSITIVE DRAINAGE.
3. IF SLOPE TOWARDS THE ROAD EXCEEDS 2", CONSTRUCT A 6" TO 8" HIGH WATER BAR (RIDGE) WITH 3:1 SIDE SLOPES ACROSS THE FOUNDATION AREA ABOUT 15" FROM THE ENTRANCE TO DIVERT RUNOFF AWAY FROM THE ROAD.
4. IF NEEDED, INSTALL PIPE UNDER PAD TO MAINTAIN PROPER PUBLIC ROAD DRAINAGE.
5. IF WET CONDITIONS ARE ANTICIPATED, PLACE GEOTEXTILE FABRIC ON THE GRADED FOUNDATION TO IMPROVE STABILITY.
6. DIVERT ALL SURFACE RUNOFF AND DRAINAGE FOR THE STONE PAD TO A SEDIMENT TRAP OR BASIN.

MAINTENANCE:

1. INSPECT AREA WEEKLY AFTER STORM EVENTS OR HEAVY USE.
2. RESHAPE PAD AS NEEDED FOR DRAINAGE AND RUNOFF CONTROL.
3. DRESS TOP WITH CLEAN STONE AS NEEDED.
4. IMMEDIATELY REMOVE MUD AND SEDIMENT TRACKED OR WASHED ONTO PUBLIC ROAD BY BRUSHING OR SWEERIN
5. REPAIR ANY BROKEN ROAD PAVEMENT IMMEDIATELY.

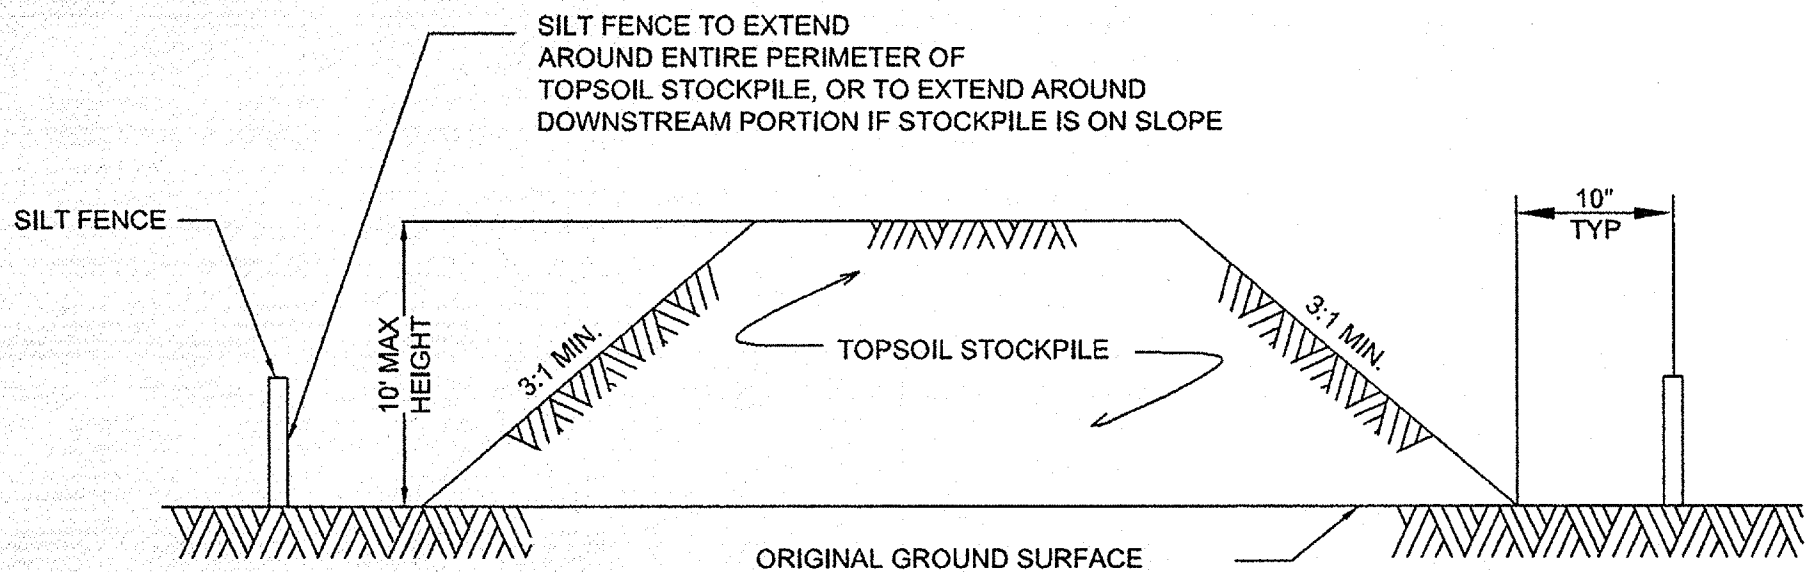

TYPICAL SOIL STOCKPILE DETAIL

SCALE: NTS

CONSTRUCTION ENTRANCE DETAIL

SCALE: NTS



Kashif J. Khan

No.	Revision/Issue	Date

INFRASTRUCTURE ENGINEERING, INC.
2601 FORTUNE CIRCLE EAST,
SUITE 201C
INDIANAPOLIS, IN 46241
PHONE: 317.243.9800
info@infrastructure-eng.com

METROPOLITAN SCHOOL DISTRICT OF
LAWRENCE TOWNSHIP

CONSTRUCTION PLANS
LAWRENCE CENTRAL HIGH SCHOOL
ATHLETIC FIELD IMPROVEMENTS

7300 East 56th Street
Indianapolis, IN 46226

EROSION CONTROL DETAILS		
Project	Sheet Number	
08-2052		
Date		
APRIL 25, 2008		
Scale		
AS NOTED	S-402	

SEASONAL SOIL PROTECTION CHART

STABILIZATION PRACTICE	JAN.	FEB.	MAR.	APR.	MAY	JUNE	JULY	AUG.	SEPT.	OCT.	NOV.	DEC.
PERMANENT SEEDING			A			*//	//	//	//	*//		
DORMANT SEEDING	B										B	
TEMPORARY SEEDING		C		E		*	//	//	//	*	D	
SODDING			F **			*	//	//	//	//	*	
MULCHING	G											

A = KENTUCKY BLUEGRASS 100 LBS./ACRE; CREEPING RED FESCUE 100 LBS./ACRE; PLUS 2 TONS STRAW MULCH/ACRE, OR ADD ANNUAL RYEGRASS 20 LBS./ACRE FERTILIZE AS RECOMMENDED BY SOIL TEST. IF TESTING IS NOT DONE, APPLY 400-600 LBS./ACRE OF 12-12-12 ANALYSIS, OR EQUIVALENT, FERTILIZER.

B = KENTUCKY BLUEGRASS 120 LBS./ACRE; CREEPING RED FESCUE 120 LBS./ACRE; PLUS 2 TONS STRAW MULCH/ACRE, OR ADD ANNUAL RYEGRASS 30 LBS./ACRE FERTILIZE AS RECOMMENDED BY SOIL TEST. IF TESTING IS NOT DONE, APPLY 400-600 LBS./ACRE OF 12-12-12 ANALYSIS, OR EQUIVALENT, FERTILIZER.

C = SPRING OATS 3 BUSHELS/ACRE FERTILIZE AS RECOMMENDED BY SOIL TEST. IF TESTING IS NOT DONE, APPLY 400-600 LBS./ACRE OF 12-12-12 ANALYSIS, OR EQUIVALENT, FERTILIZER.

D = WHEAT OR RYE 2 BUSHELS/ACRE FERTILIZE AS RECOMMENDED BY SOIL TEST. IF TESTING IS NOT DONE, APPLY 400-600 LBS./ACRE OF 12-12-12 ANALYSIS, OR EQUIVALENT, FERTILIZER.

E = ANNUAL RYEGRASS 40 LBS./ACRE (1 LB./1000 SQ. FT.) FERTILIZE AS RECOMMENDED BY SOIL TEST. IF TESTING IS NOT DONE, APPLY 400-600 LBS./ACRE OF 12-12-12 ANALYSIS, OR EQUIVALENT, FERTILIZER.

F = SOD

G = STRAW MULCH 2 TONS/ACRE

* ///* = IRRIGATION NEEDED DURING JUNE, JULY, AUGUST AND/OR SEPTEMBER

** = IRRIGATION NEEDED FOR 2 WEEKS AFTER SUPPLYING SOD

SCALE: NTS

2" x 2" x 48" FENCE POSTS SPACED 5' O.C.

6' ±

2" LATH

SILT FENCE FABRIC

6" x 6" FARM FIELD TYPE FENCE

25" MIN.

COMPACTED SOIL OVER SILT FENCE

TOE OF SLOPE

6"

6"

MOUND EARTH OVER TOE OF SILT FENCE

12" MIN.

DOWNHILL SIDE

SILT FENCE


 
SCALE: NTS


Diagram illustrating the construction of a trench barrier. The barrier is formed by a mesh material held in place by vertical stakes. The stakes are secured at the top with nylon cord and secured near the ground with nylon cord.

 HOLEY MOLEY SAYS
"DON'T
DIG
BLIND"



"IT'S THE LAW
 CALL 2 WORKING DAYS BEFORE YOU
1-800-382-554
 CALL TOLL FREE
 PER INDIANA STATE LAW IS-69-3
 IT IS AGAINST THE LAW TO EXCAVATE
 WITHOUT NOTIFYING THE UNDERGROUND
 LOCATION SERVICE TWO (2) WORKING
 DAYS BEFORE COMMENCING WORK




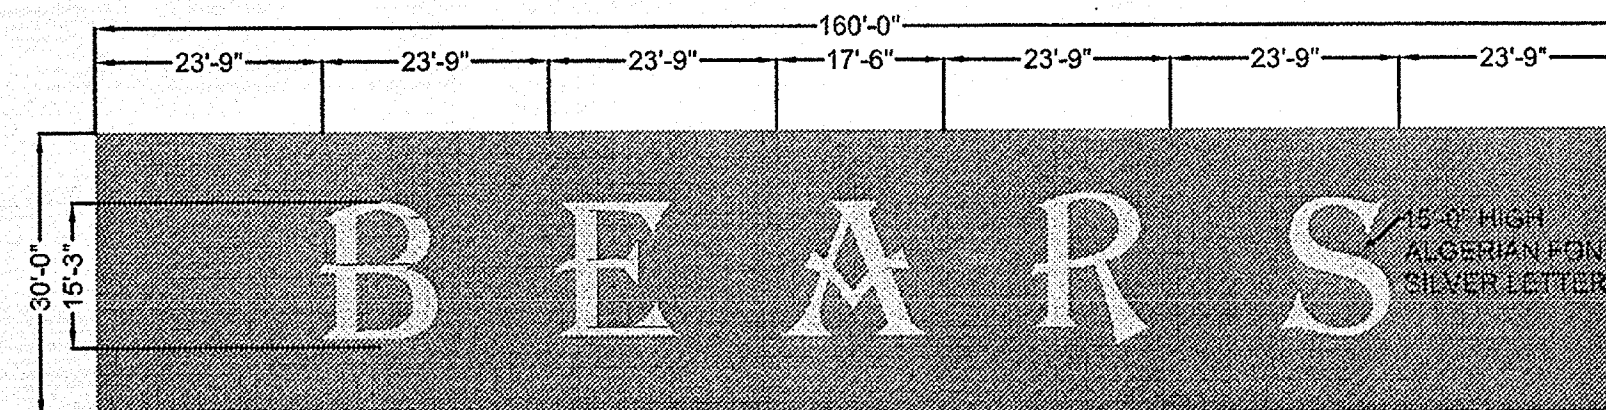

NOTE:
SHADOW OF ALGERIAN FONT TO BE BLACK INLAID SYNTHETIC TURF.


END ZONE LETTERING DETAIL

SCALE: 1" = 20'-0"

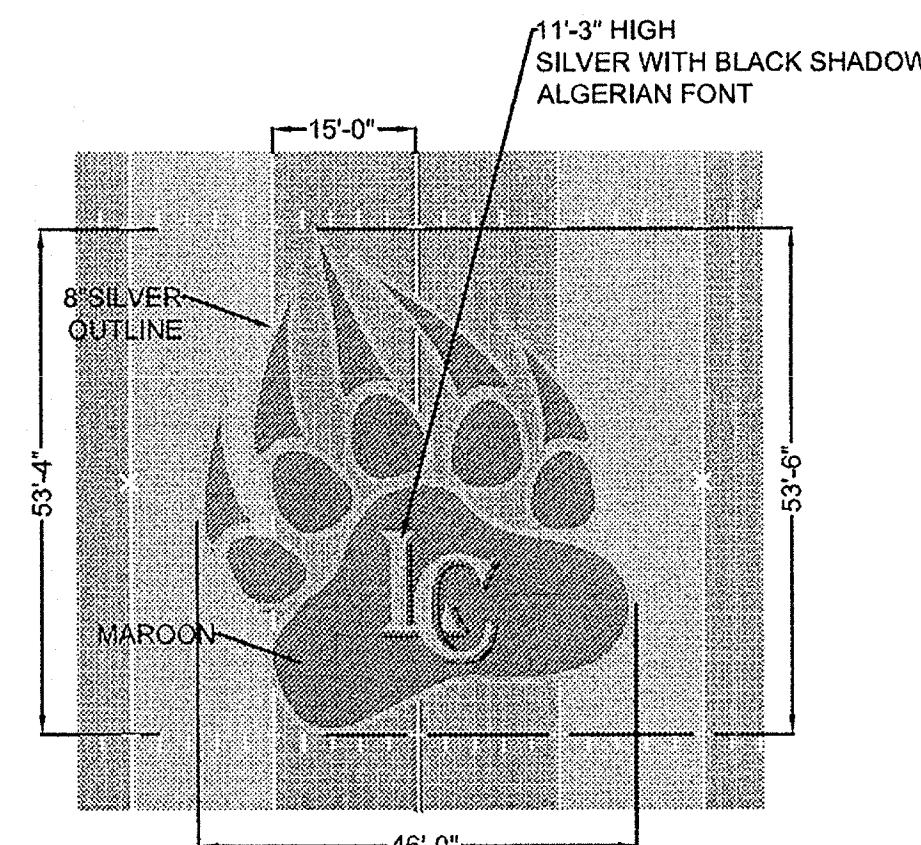


CENTER FIELD LOGO DETAIL

SCALE: 1" = 20'-0"

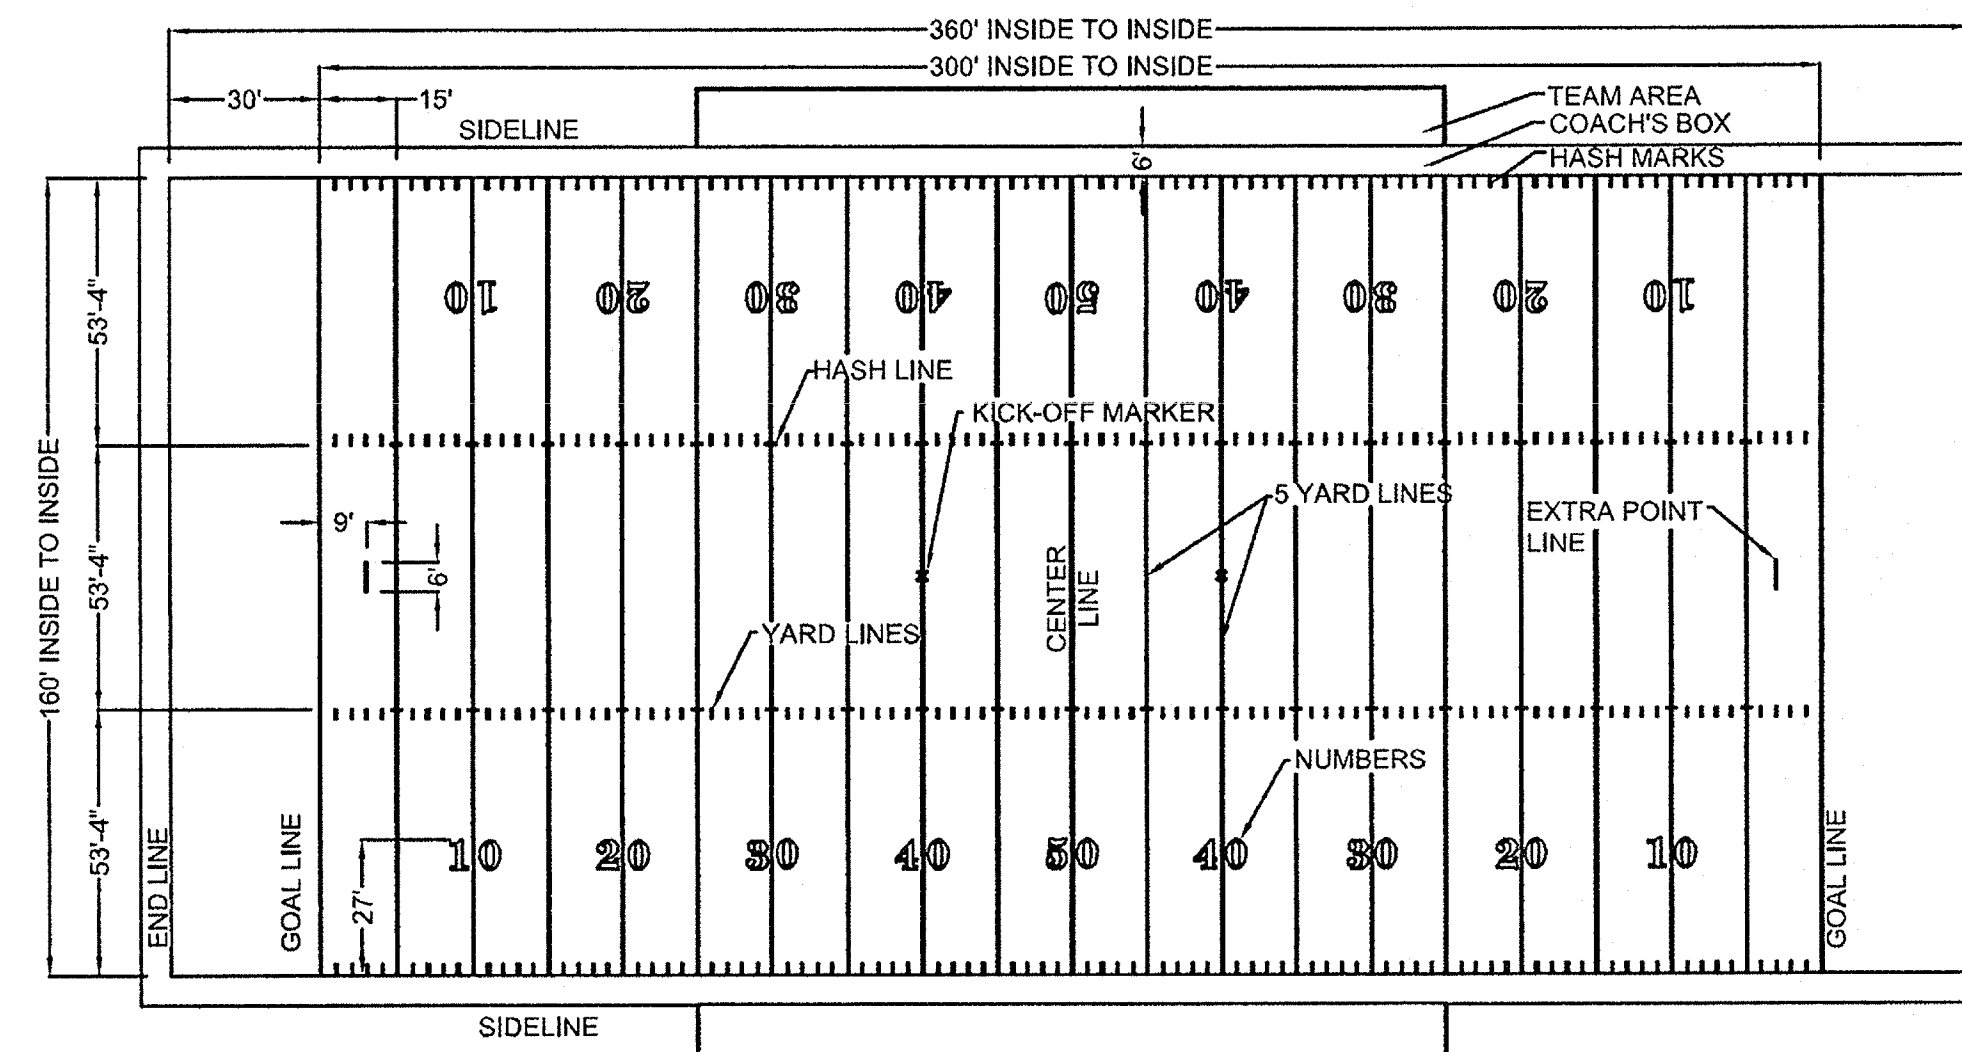


FIELD DETAIL

SCALE: NTS

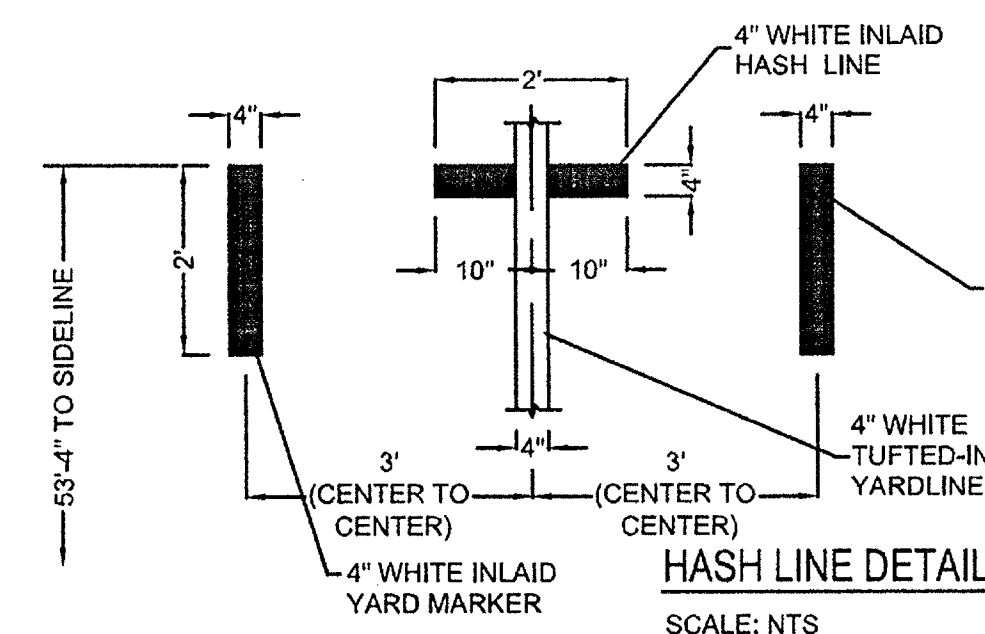


HASH LINE DETAIL

SCALE: NTS

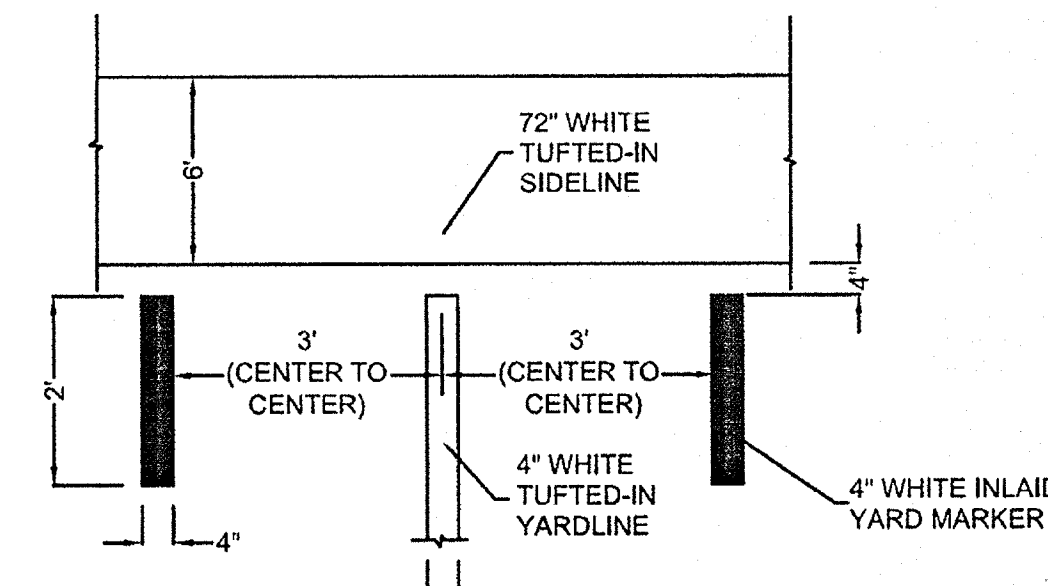

SIDE LINE DETAIL

SCALE: NTS

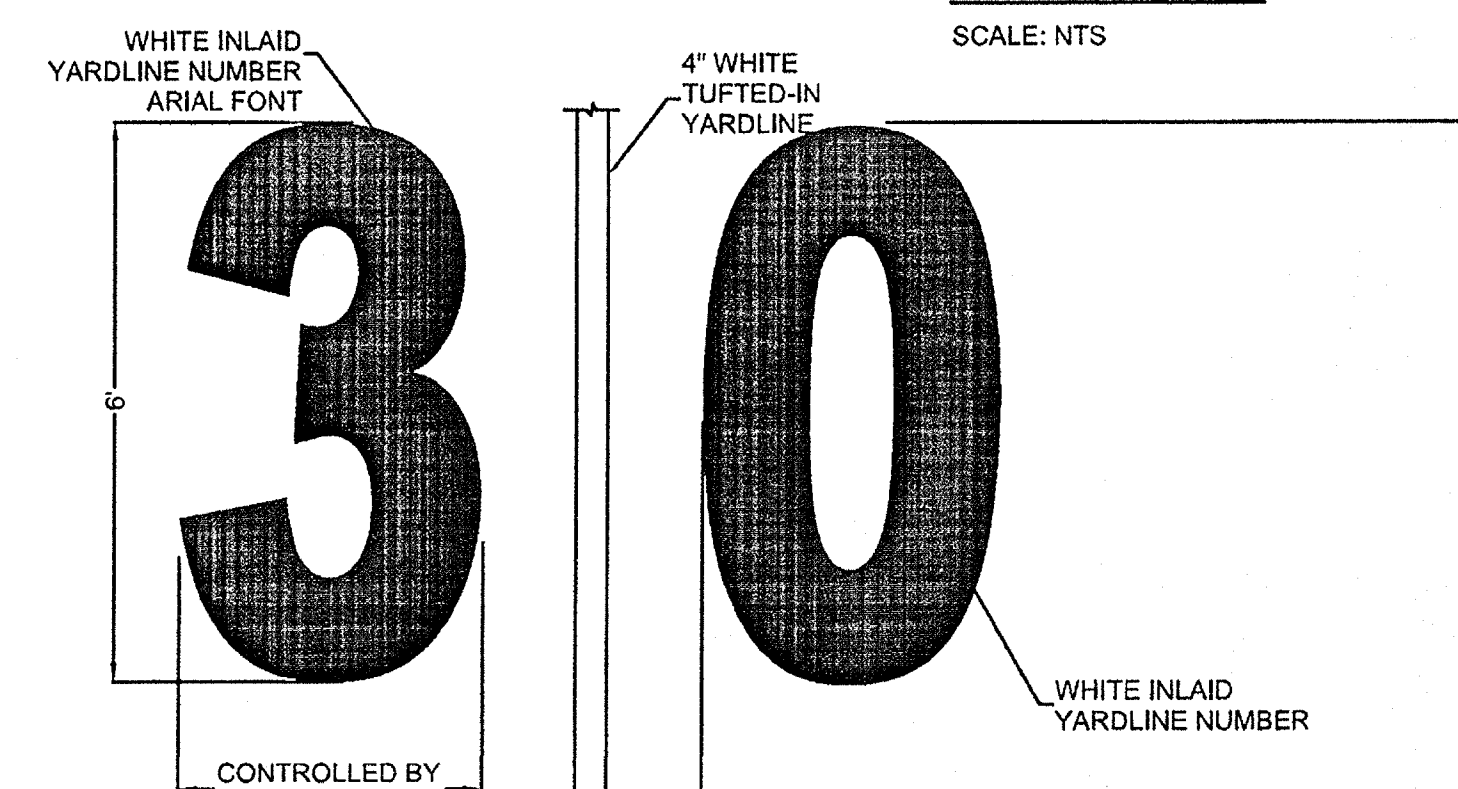

LEGEND:

- TUFTED WHITE LINE (INDICATED ON DETAILS ONLY)
- INLAID WHITE LINE (INDICATED ON DETAILS ONLY)

FOOTBALL LAYOUT NOTES

SIDELINES, YARDLINES, AND PERIMETER BORDER ARE TUFTED-IN WHITE LINES AS PER DETAILS.
INBOUNDS LINES, SHORT YARD MARKERS, EXTRA POINT MARKERS AND ALL OTHER FIELD MARKINGS ARE TO BE INLAID TURF.


ALL DIMENSIONS TO BE VERIFIED BEFORE ANY CONSTRUCTION BEGINS

YARDLINE NUMBERS

SCALE: NTS


LEGEND:

- SYNTHETIC TURF WHITE (PANTONE WHITE)
- SYNTHETIC TURF BLACK (PANTONE BLACK 6 C)
- SYNTHETIC TURF MAROON (PANTONE 195 C)
- SYNTHETIC TURF SILVER (PANTONE 877C)
- SYNTHETIC TURF FIELD GREEN (PANTONE FIELD GREEN) OR ENGINEER APPROVED EQUAL
- SYNTHETIC TURF SUMMER GREEN (PANTONE SUMMER GREEN) OR ENGINEER APPROVED EQUAL

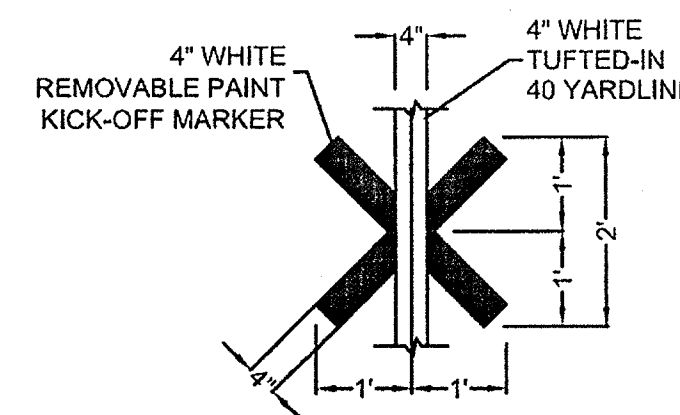


KICKOFF MARKER

SCALE: NTS

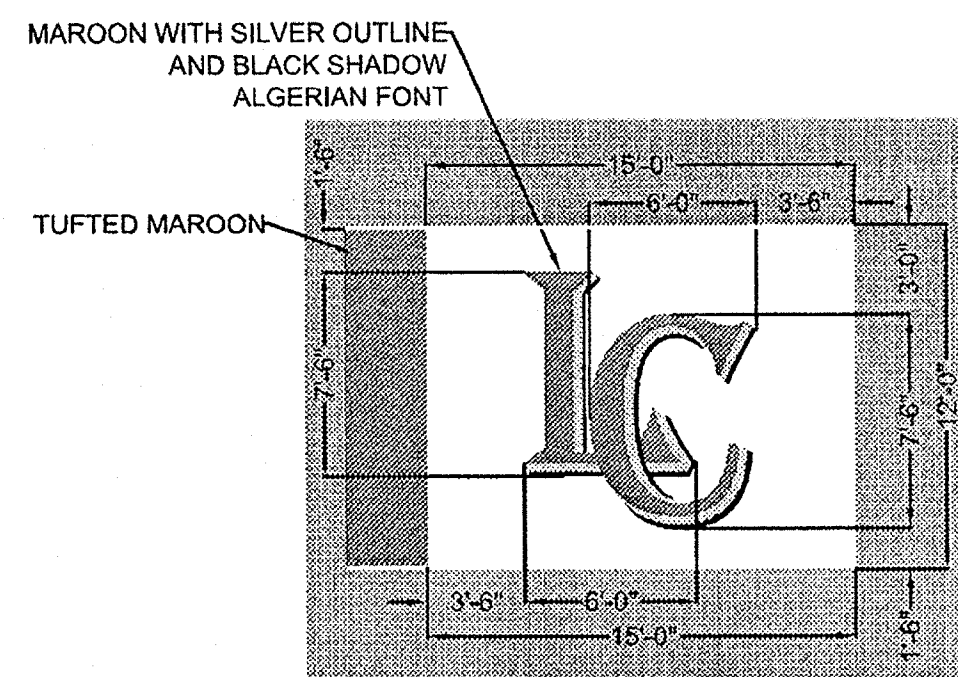


PLAYER BOX END CAP LOGO DETAIL

SCALE: 1" = 10'-0"

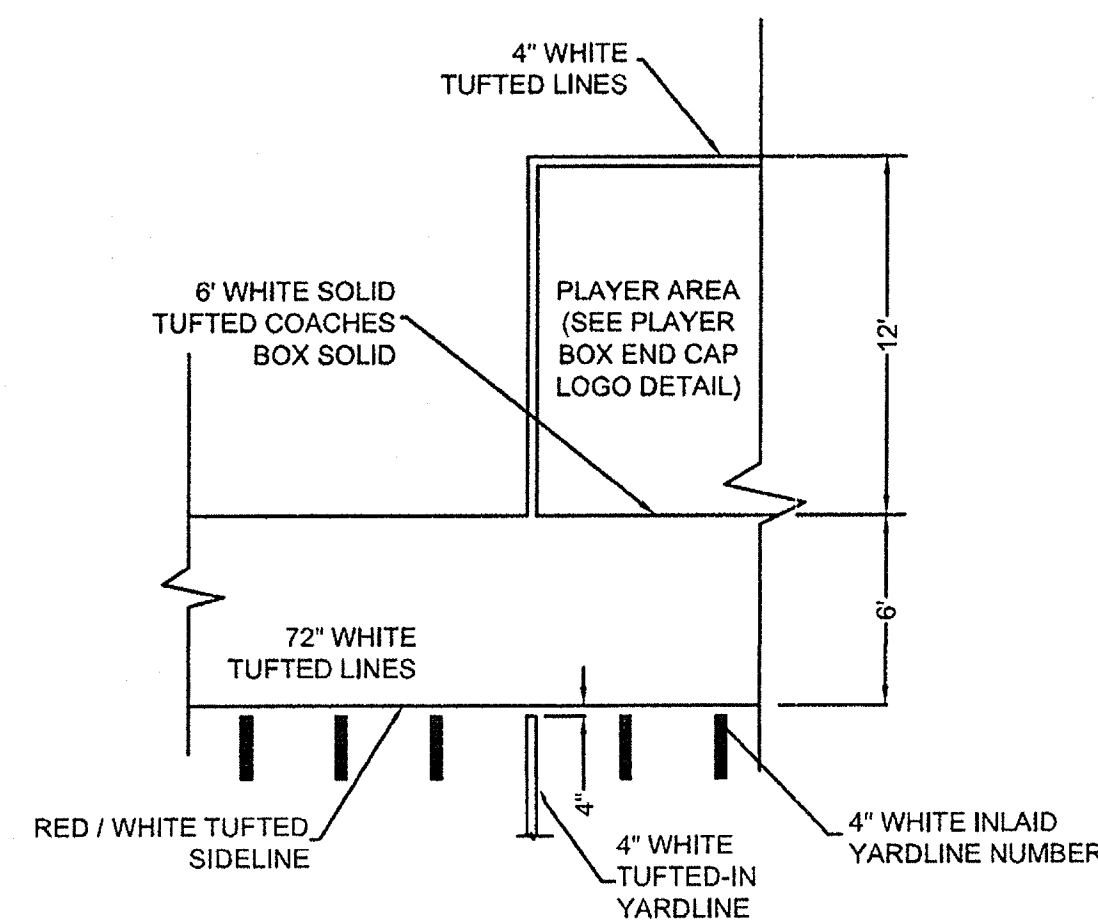

COACHES BOX DETAIL

SCALE: NTS

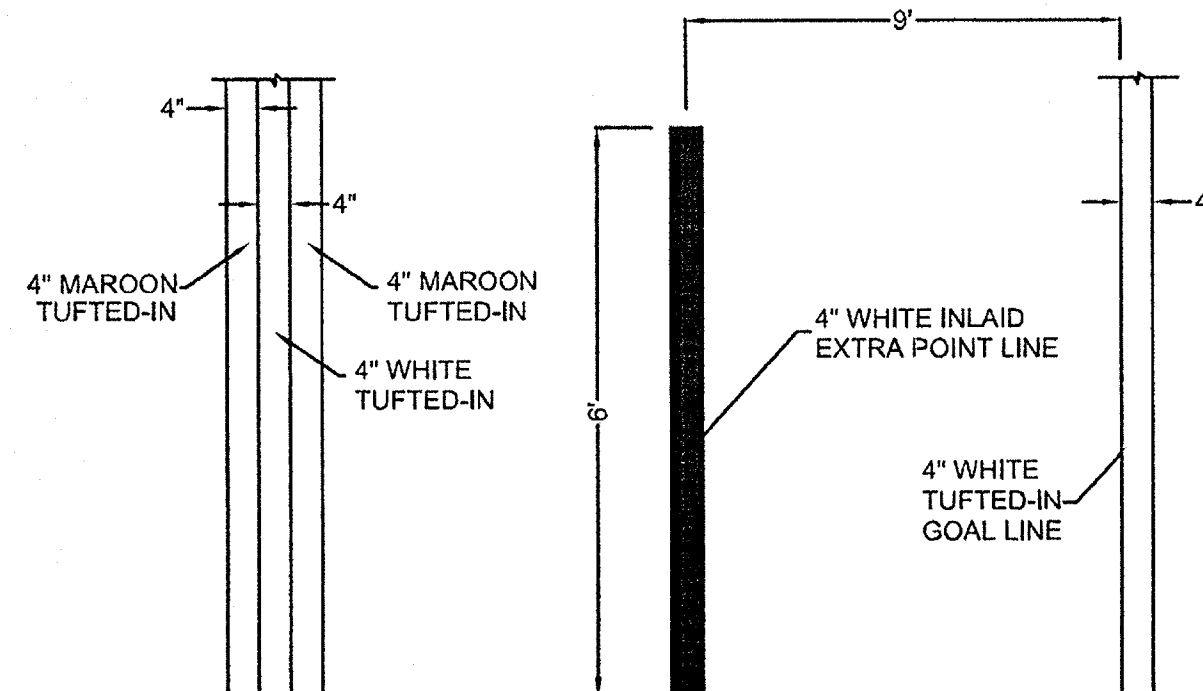


50 & 20 YARD LINE DETAIL

SCALE: NTS

EXTRA POINT LINE DETAIL

SCALE: NTS

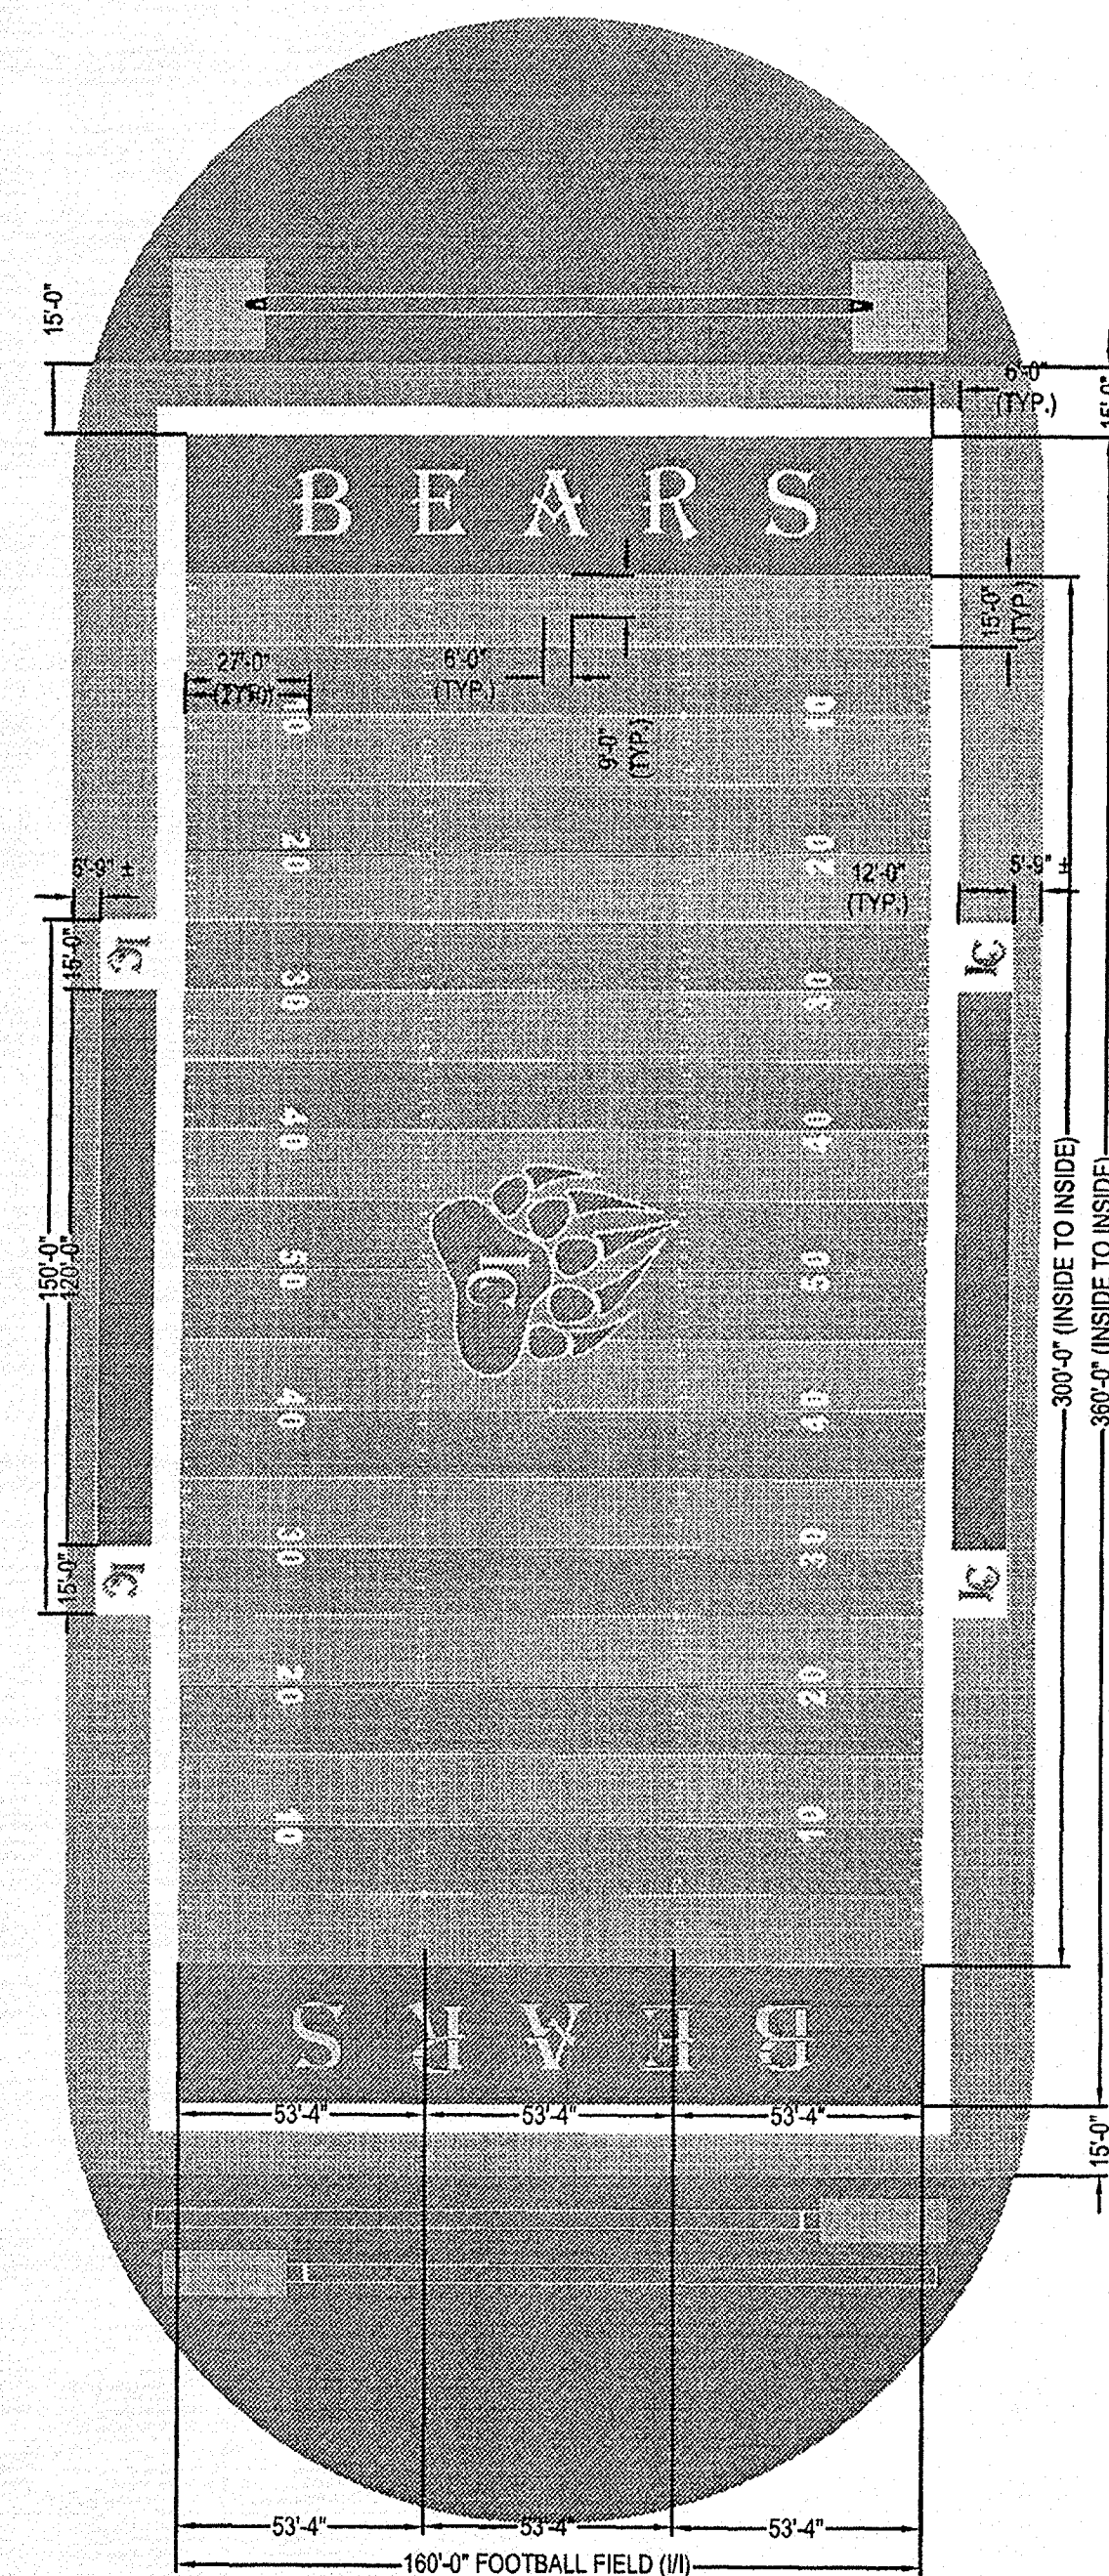

FIELD LAYOUT

SCALE: 1" = 40'-0"



Kashif J. Khan

No.	Revision/Issue	Date




INFRASTRUCTURE ENGINEERING, INC.
2601 FORTUNE CIRCLE EAST,
SUITE 201C
INDIANAPOLIS, IN 46241
PHONE: 317.243.9800
info@infrastructure-eng.com

METROPOLITAN SCHOOL DISTRICT OF
LAWRENCE TOWNSHIP
CONSTRUCTION PLANS
LAWRENCE CENTRAL HIGH SCHOOL
ATHLETIC FIELD IMPROVEMENTS
7300 East 56th Street
Indianapolis, IN 46226



FIELD LAYOUT		
Project	08-2052	Sheet Number
Date	APRIL 25, 2008	
Scale	AS NOTED	S-500



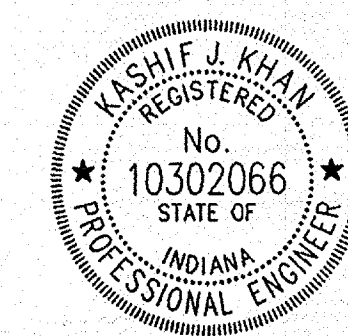

Kashif J. Khan

GRATE OPTIONS	LOAD RATING
PEDESTRIAN STANDARD	LIGHT DUTY
SOLID COVER	LIGHT DUTY
BRONZE	LIGHT DUTY
DOME	N/A
DROP IN GRATE	LIGHT DUTY

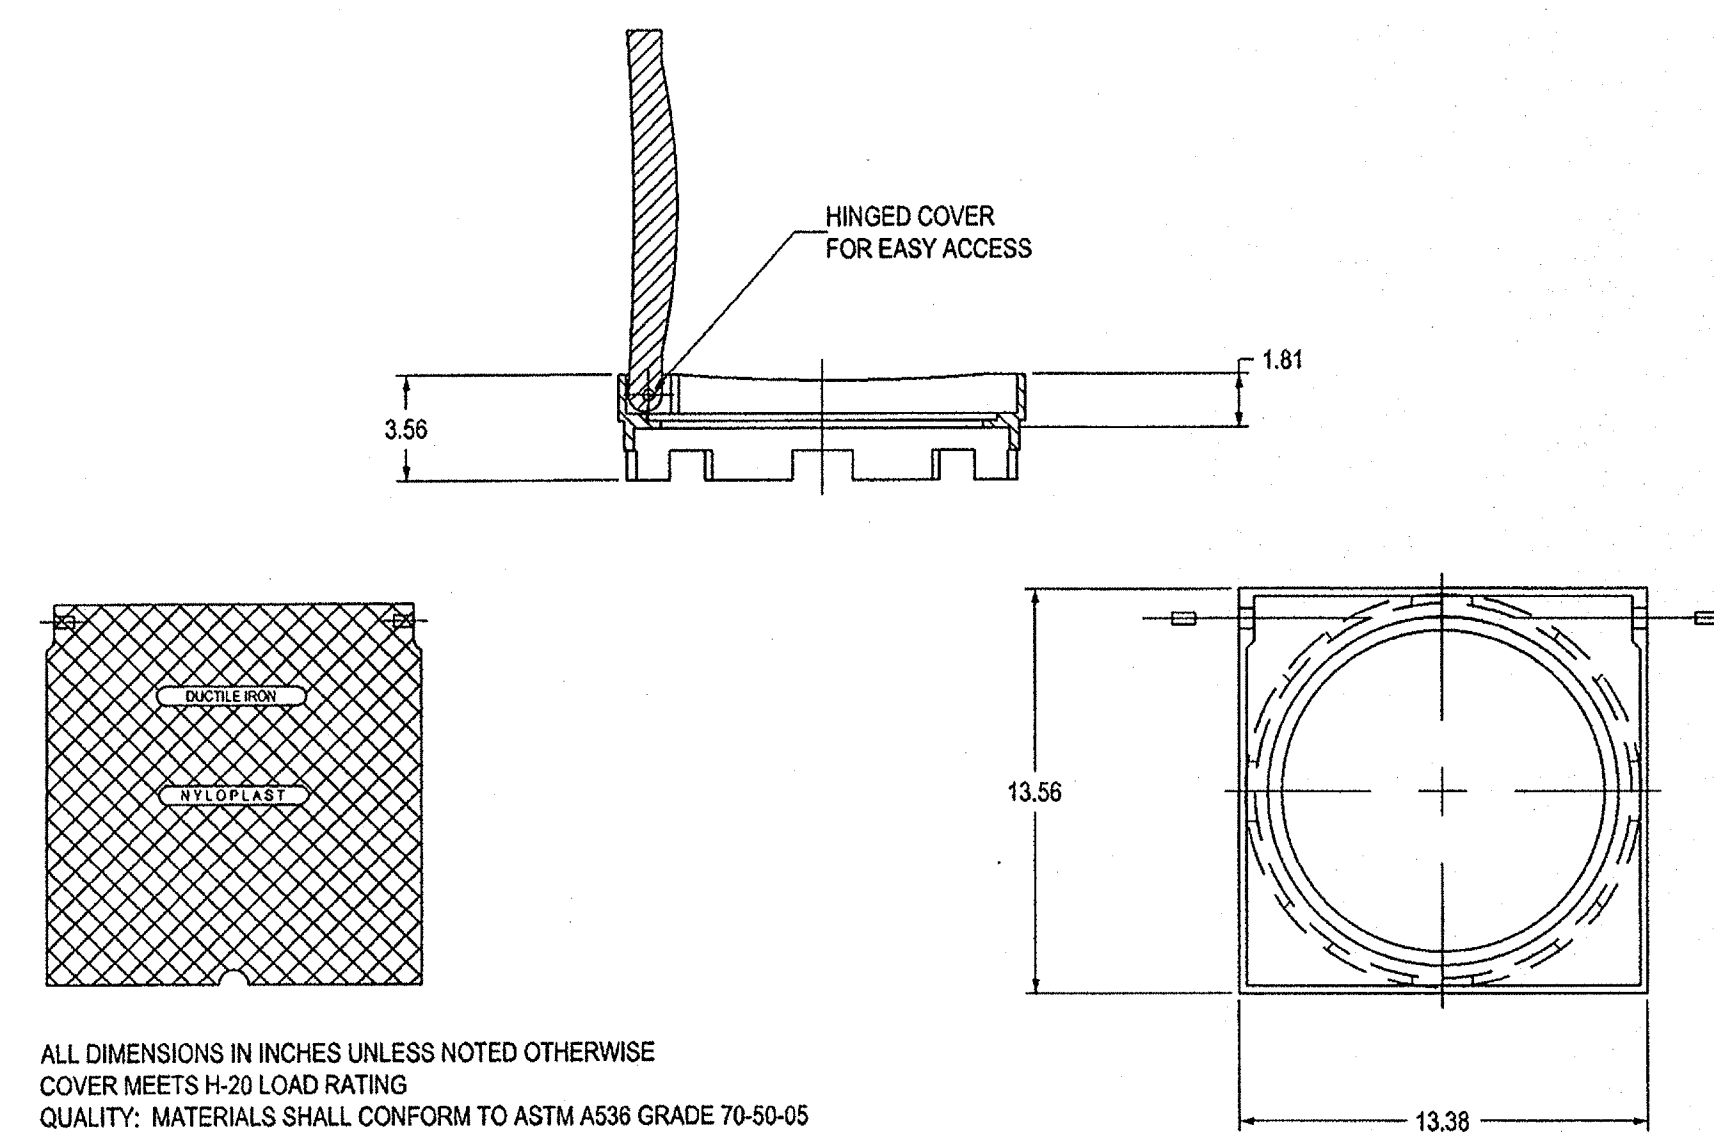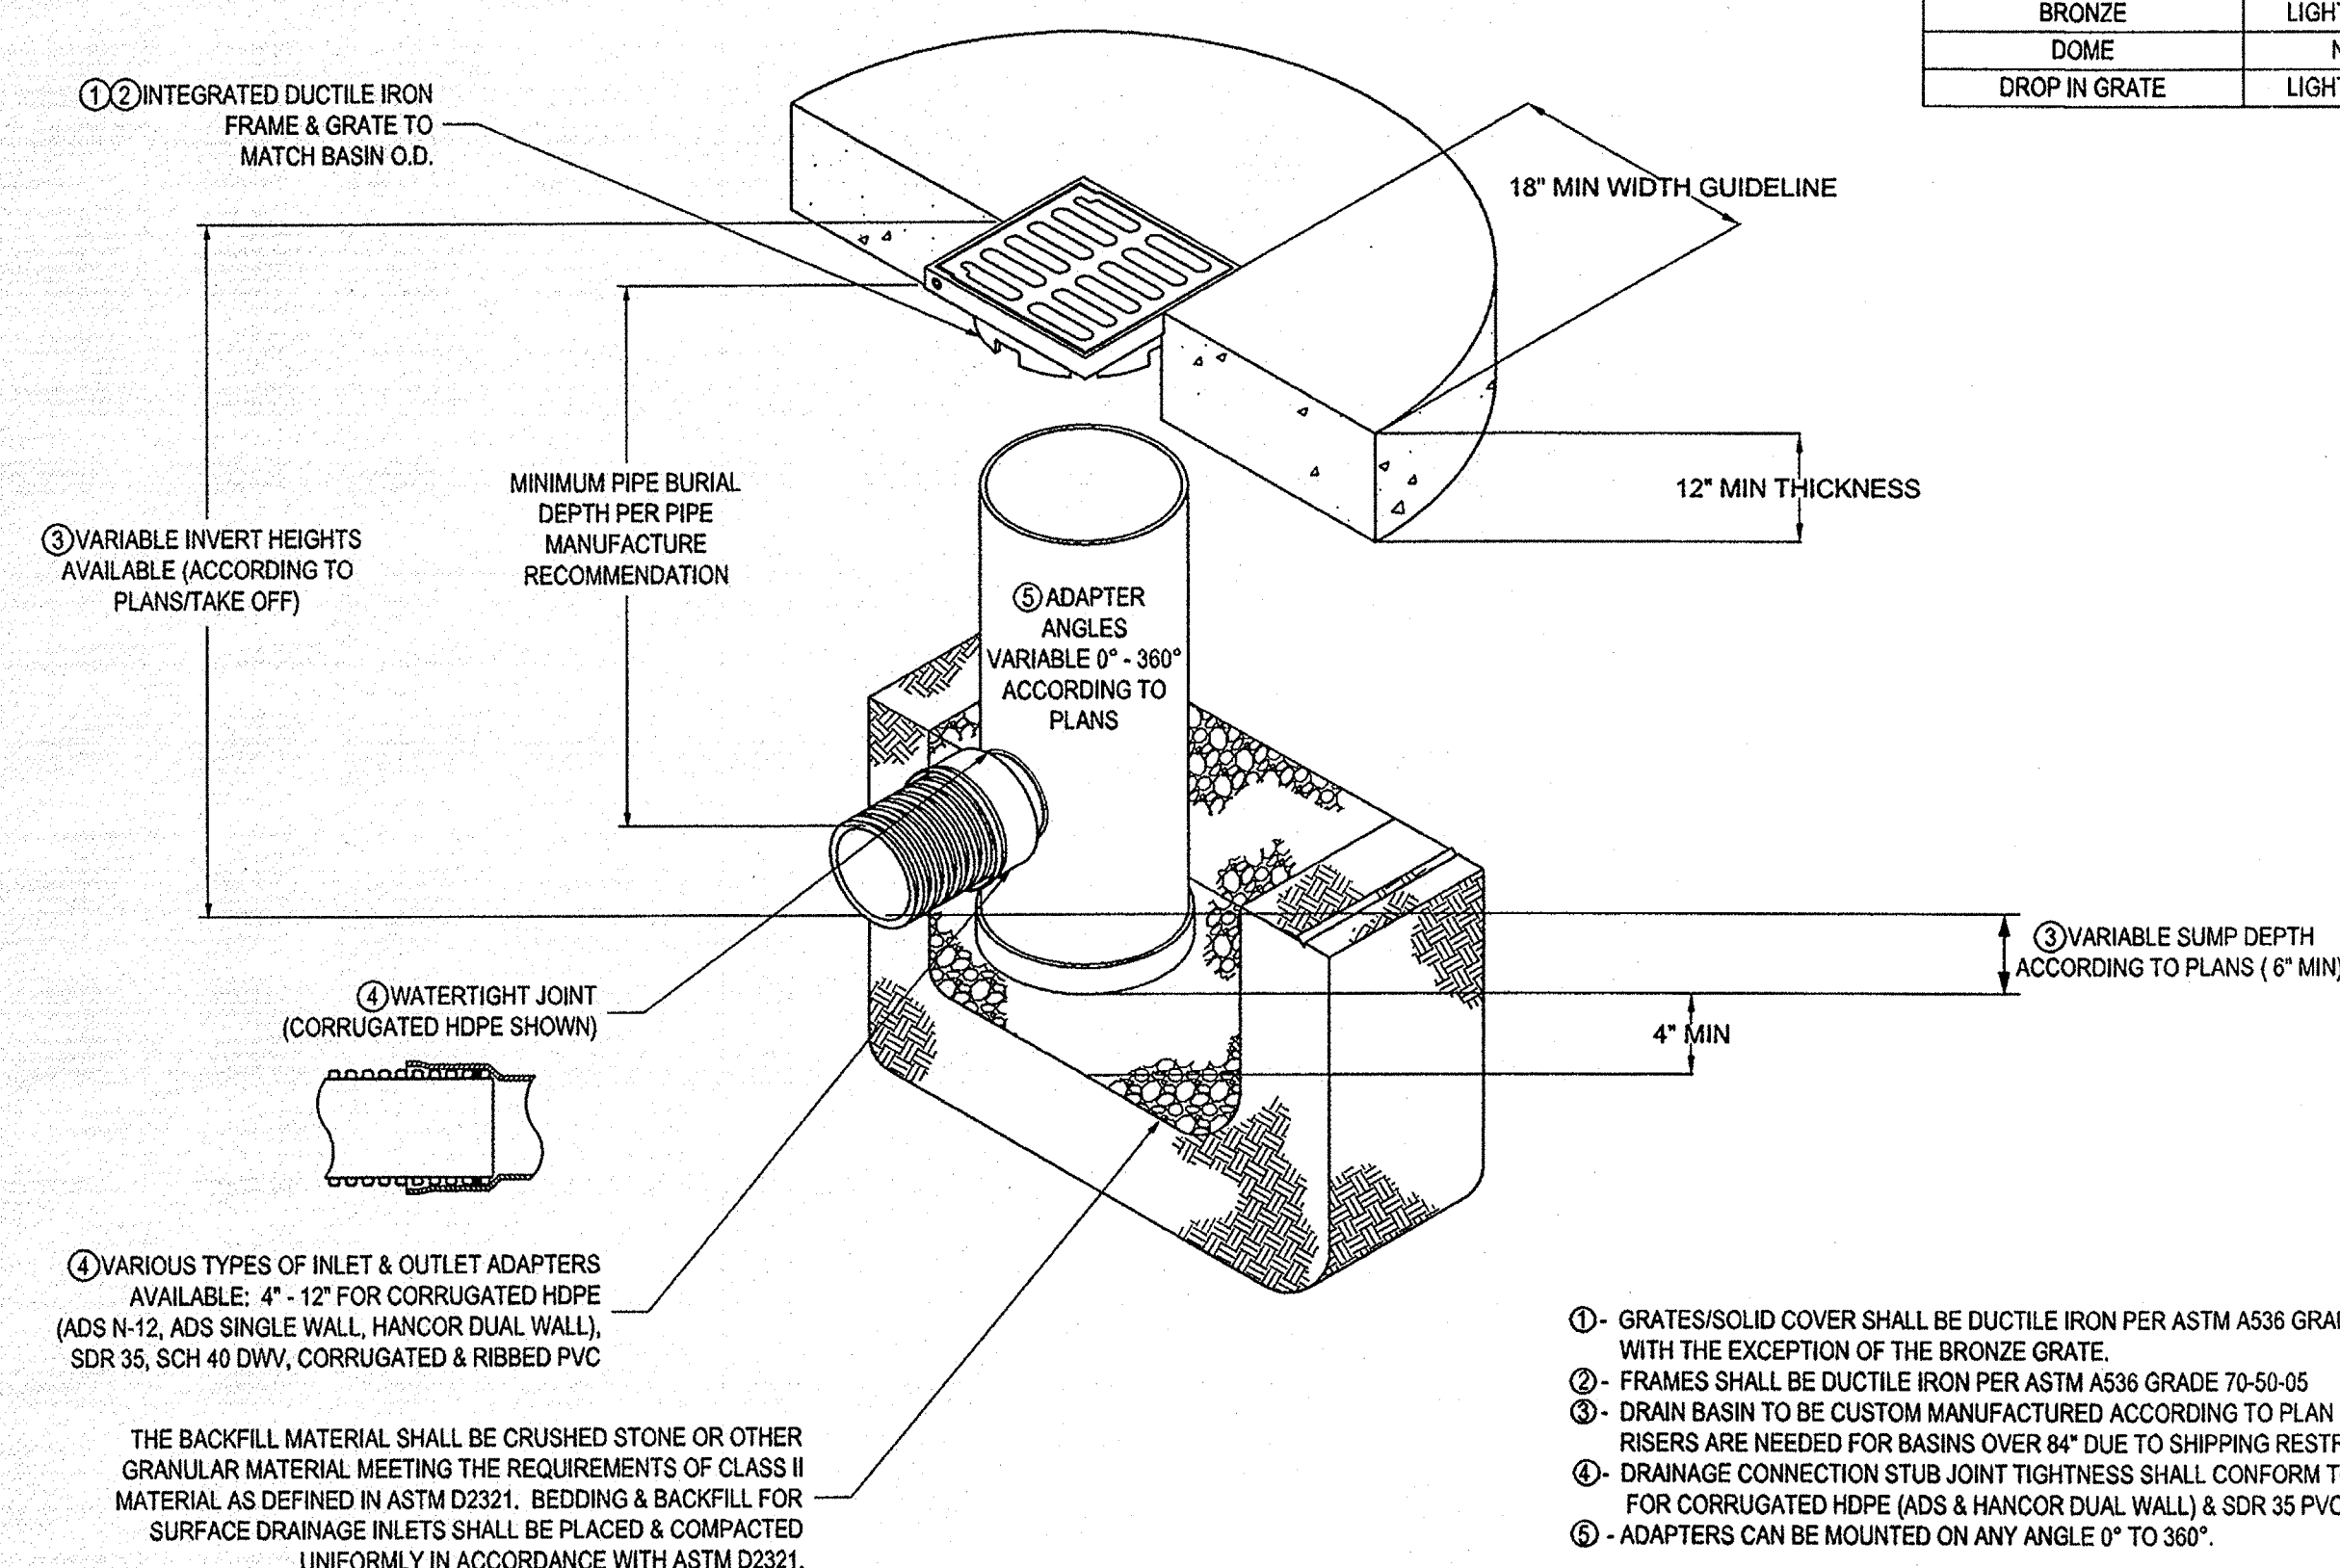

ALL DIMENSIONS IN INCHES UNLESS NOTED OTHERWISE
COVER MEETS H-20 LOAD RATING
QUALITY: MATERIALS SHALL CONFORM TO ASTM A536 GRADE 70-50-05
PAINT: CASTINGS ARE FURNISHED WITH A BLACK PAINT


1299CGC
APPROX. WEIGHT WITH FRAME = 39.90 LBS
12" SOLID COVER ASSEMBLY
SCALE: NTS

- 1. GRATES/SOLID COVER SHALL BE DUCTILE IRON PER ASTM A536 GRADE 70-50-05, WITH THE EXCEPTION OF THE BRONZE GRATE.
- 2. FRAMES SHALL BE DUCTILE IRON PER ASTM A536 GRADE 70-50-05.
- 3. DRAIN BASIN TO BE CUSTOM MANUFACTURED ACCORDING TO PLAN DETAILS. RISERS ARE NEEDED FOR BASINS OVER 8" DUE TO SHIPPING RESTRICTIONS.
- 4. DRAINAGE CONNECTION SUB JOINT TIGHTNESS SHALL CONFORM TO ASTM D3212 FOR CORRUGATED HDPE (ADS & HANCOR DUAL WALL) & SDR 35 PVC.
- 5. ADAPTERS CAN BE MOUNTED ON ANY ANGLE 0° TO 360°.


THE BACKFILL MATERIAL SHALL BE CRUSHED STONE OR OTHER GRANULAR MATERIAL MEETING THE REQUIREMENTS OF CLASS II MATERIAL AS DEFINED IN ASTM D2321. BEDDING & BACKFILL FOR SURFACE DRAINAGE INLETS SHALL BE PLACED & COMPACTED UNIFORMLY IN ACCORDANCE WITH ASTM D2321.

12" CLEANOUT / DRAIN BASIN:
SCALE: NTS

BODY SIZE	ADAPTER SIZE	A ±1.00
8"	4"	6.20
8"	6"	6.20
8"	8"	6.70
10"	4"	7.25
10"	6"	7.25
10"	8"	7.75
12"	4"	8.25
12"	6"	8.25
12"	8"	8.75
12"	10"	9.75
12"	12"	9.25
15"	4"	9.65
15"	6"	9.65
15"	8"	10.15
15"	10"	10.15
15"	12"	10.65
15"	15"	10.65
18"	4"	11.35
18"	6"	11.35
18"	8"	11.85
18"	10"	11.85
18"	12"	12.35
18"	15"	12.35
18"	18"	12.85
24"	4"	14.40
24"	6"	14.40
24"	8"	14.90
24"	10"	14.90
24"	12"	15.40
24"	15"	15.40
24"	18"	15.90
24"	24"	16.90
30"	4"	18.00
30"	6"	18.00
30"	8"	18.50
30"	10"	18.50
30"	12"	19.00
30"	15"	19.00
30"	18"	19.50
30"	24"	20.50
30"	30"	27.00

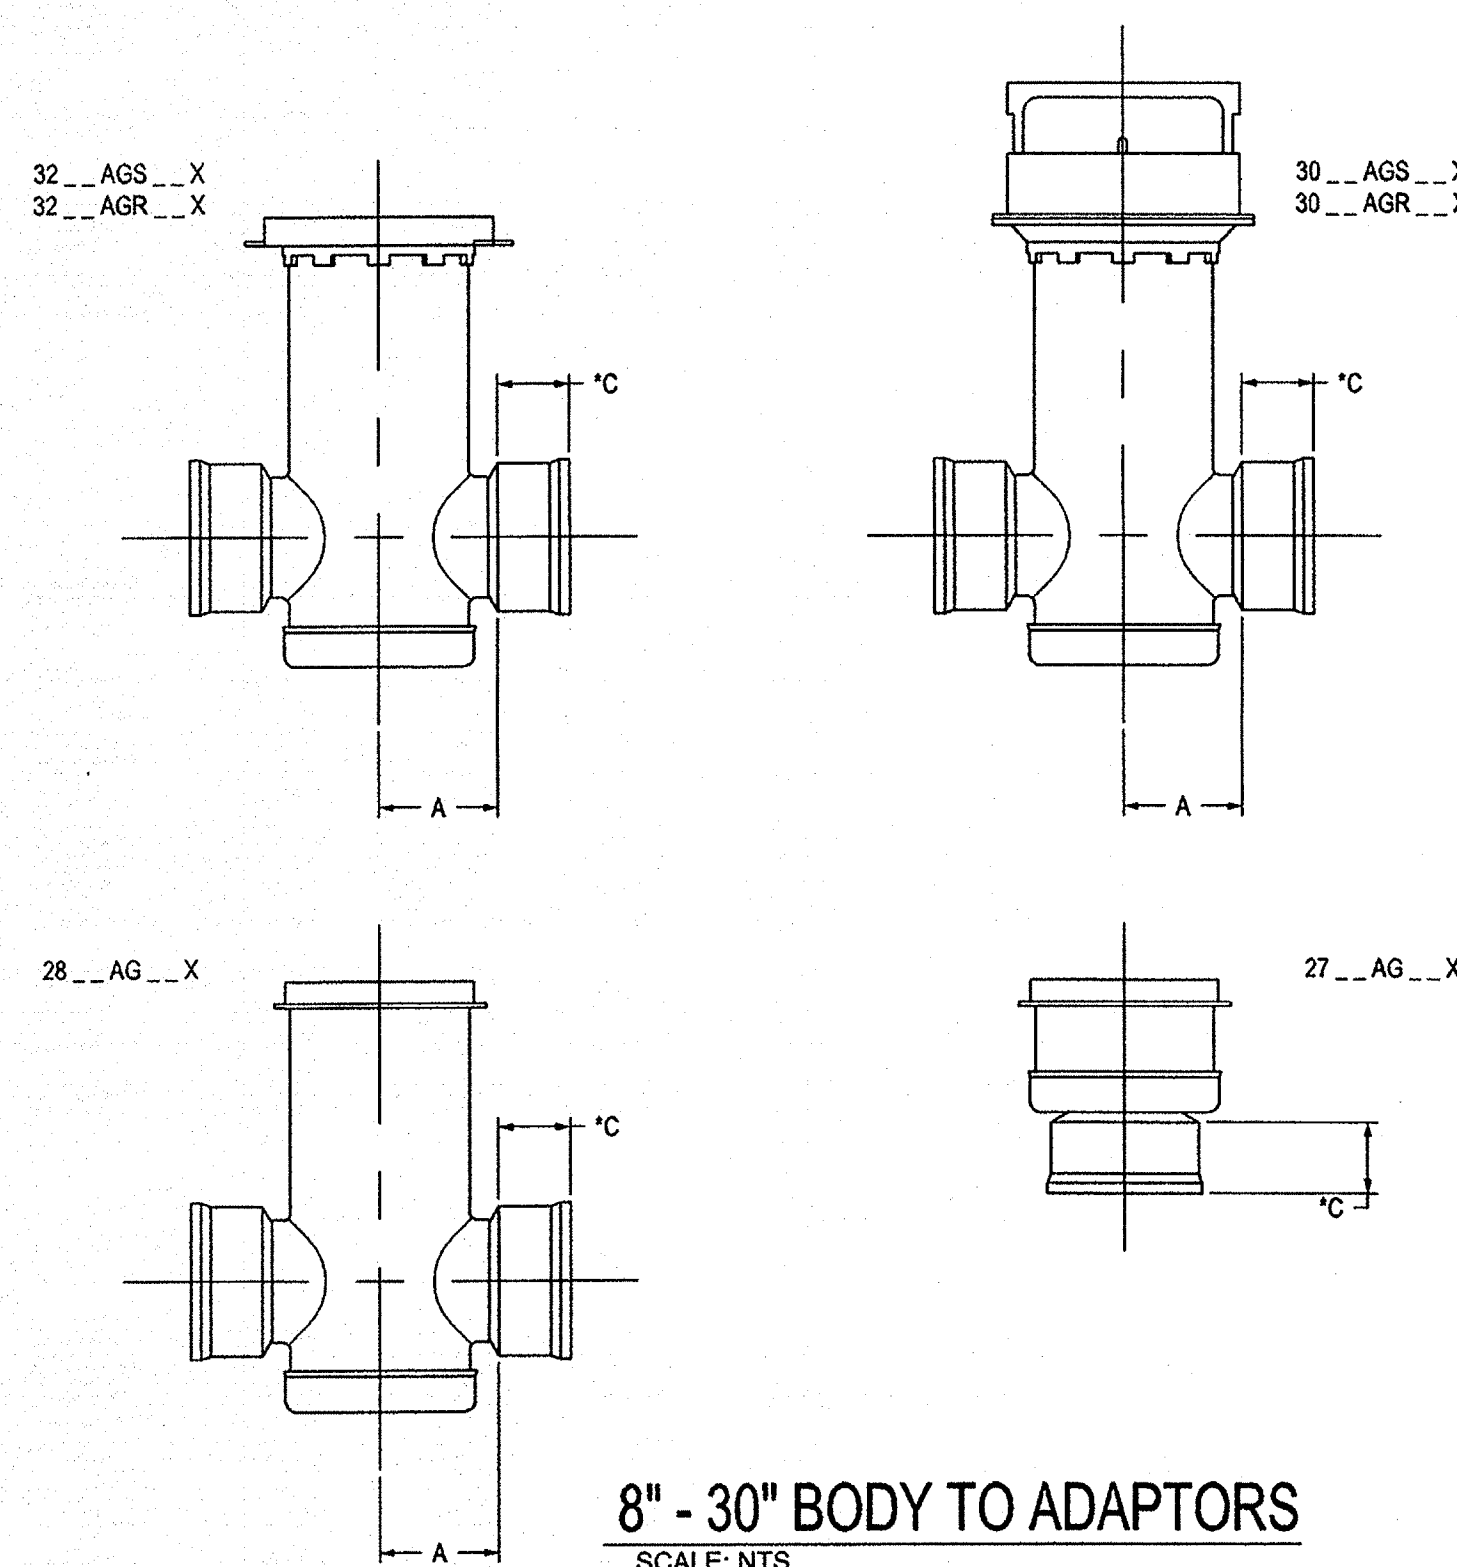

8" - 30" BODY TO ADAPTORS
SCALE: NTS

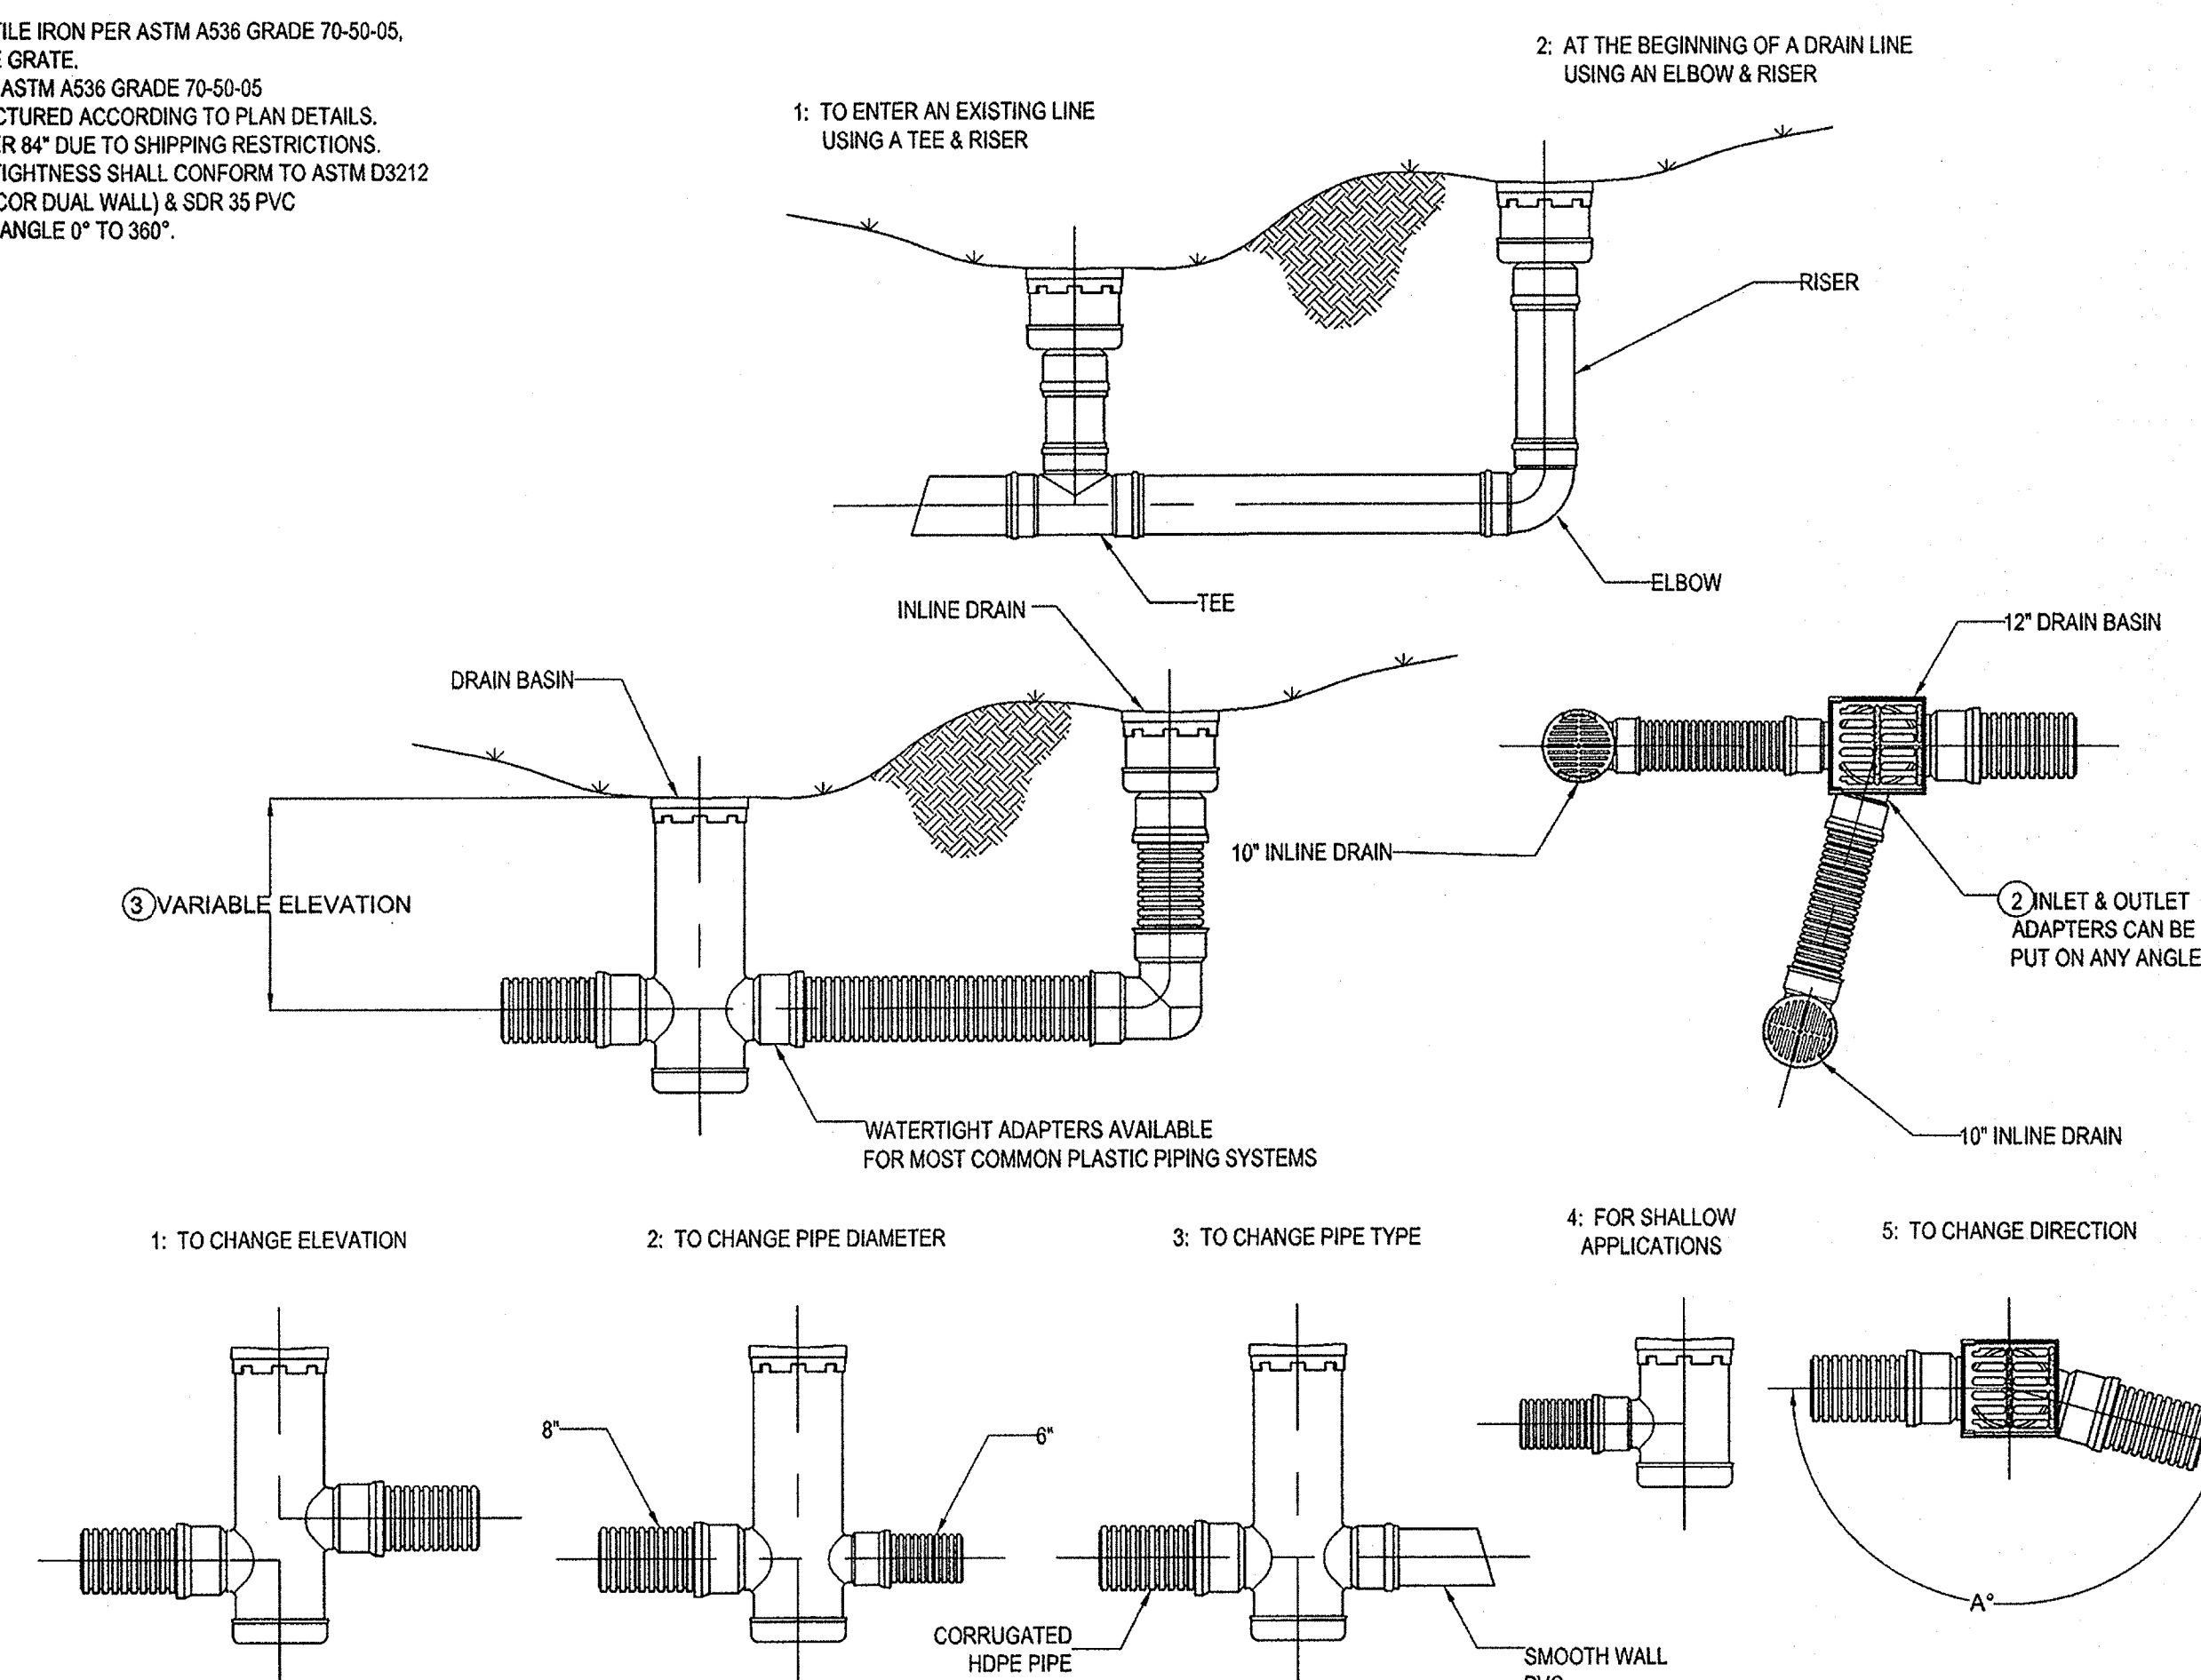

8 IN. - 30 IN TYPICAL INSTALLATION
SCALE: NTS



No.	Revision/Issue	Date

INFRASTRUCTURE ENGINEERING, INC.
2601 FORTUNE CIRCLE EAST,
SUITE 201C
INDIANAPOLIS, IN 46241
PHONE: 317.243.9800
info@infrastructure-eng.com


METROPOLITAN SCHOOL DISTRICT OF
LAWRENCE TOWNSHIP

CONSTRUCTION PLANS
LAWRENCE CENTRAL HIGH SCHOOL
ATHLETIC FIELD IMPROVEMENTS

7300 East 56th Street
Indianapolis, IN 46226

STANDARD DETAILS	
Project	08-2052
Date	APRIL 25, 2008
Scale	AS NOTED
Sheet Number	S-502


- * PLEASE SEE ACCOMPANIED AQUA-SWIRL SPECIFICATION NOTES.
 ** SEE SITE PLAN FOR ACTUAL SYSTEM ORIENTATION.
 *** ORIENTATION MAY VARY FROM 90°, 180°, OR CUSTOM ANGLES TO MEET SITE CONDITIONS.

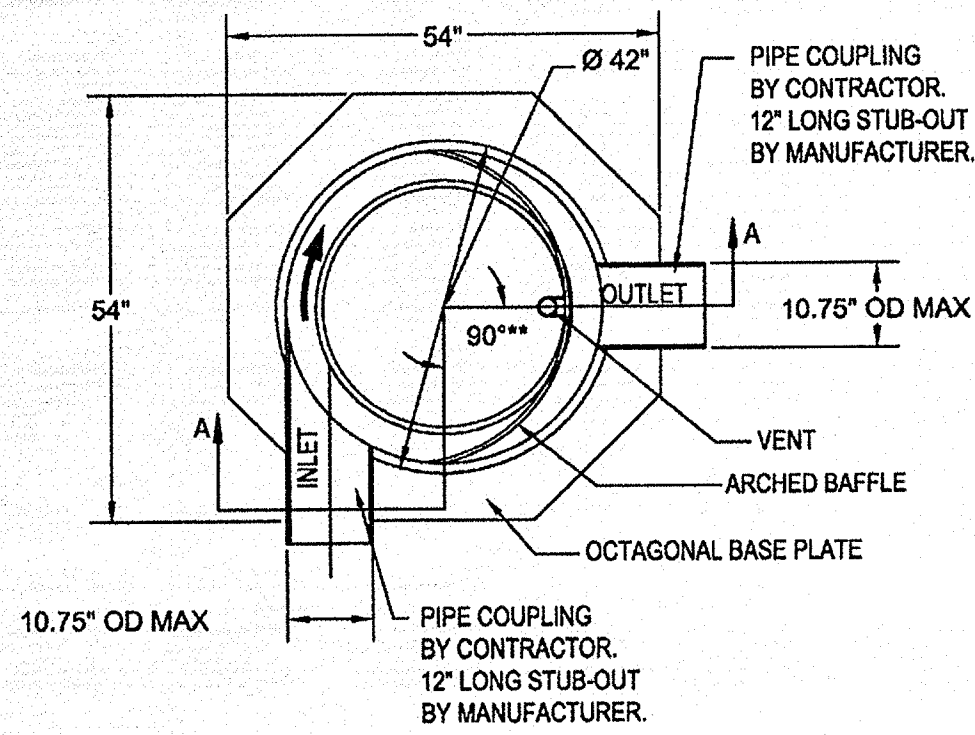

PLAN VIEW

NOTE:

1. SYSTEM SHALL BE DESIGNED FOR THE FOLLOWING CAPACITIES:
 PEAK TREATMENT FLOW: 1.1 CFS
 SEDIMENT STORAGE: 10 FT³
 OIL/DEBRIS STORAGE: 37 GAL.
2. CONTRACTOR MAY SUBMIT ALTERNATE STORMWATER TREATMENT STRUCTURE FOR REVIEW & APPROVAL. THE PROPOSED ALTERNATE SHALL BE ON THE INDIANAPOLIS DPW PRE-APPROVED LIST OF STRUCTURES.
 MINIMUM REQUIRED TREATMENT FLOW = 0.36 CFS

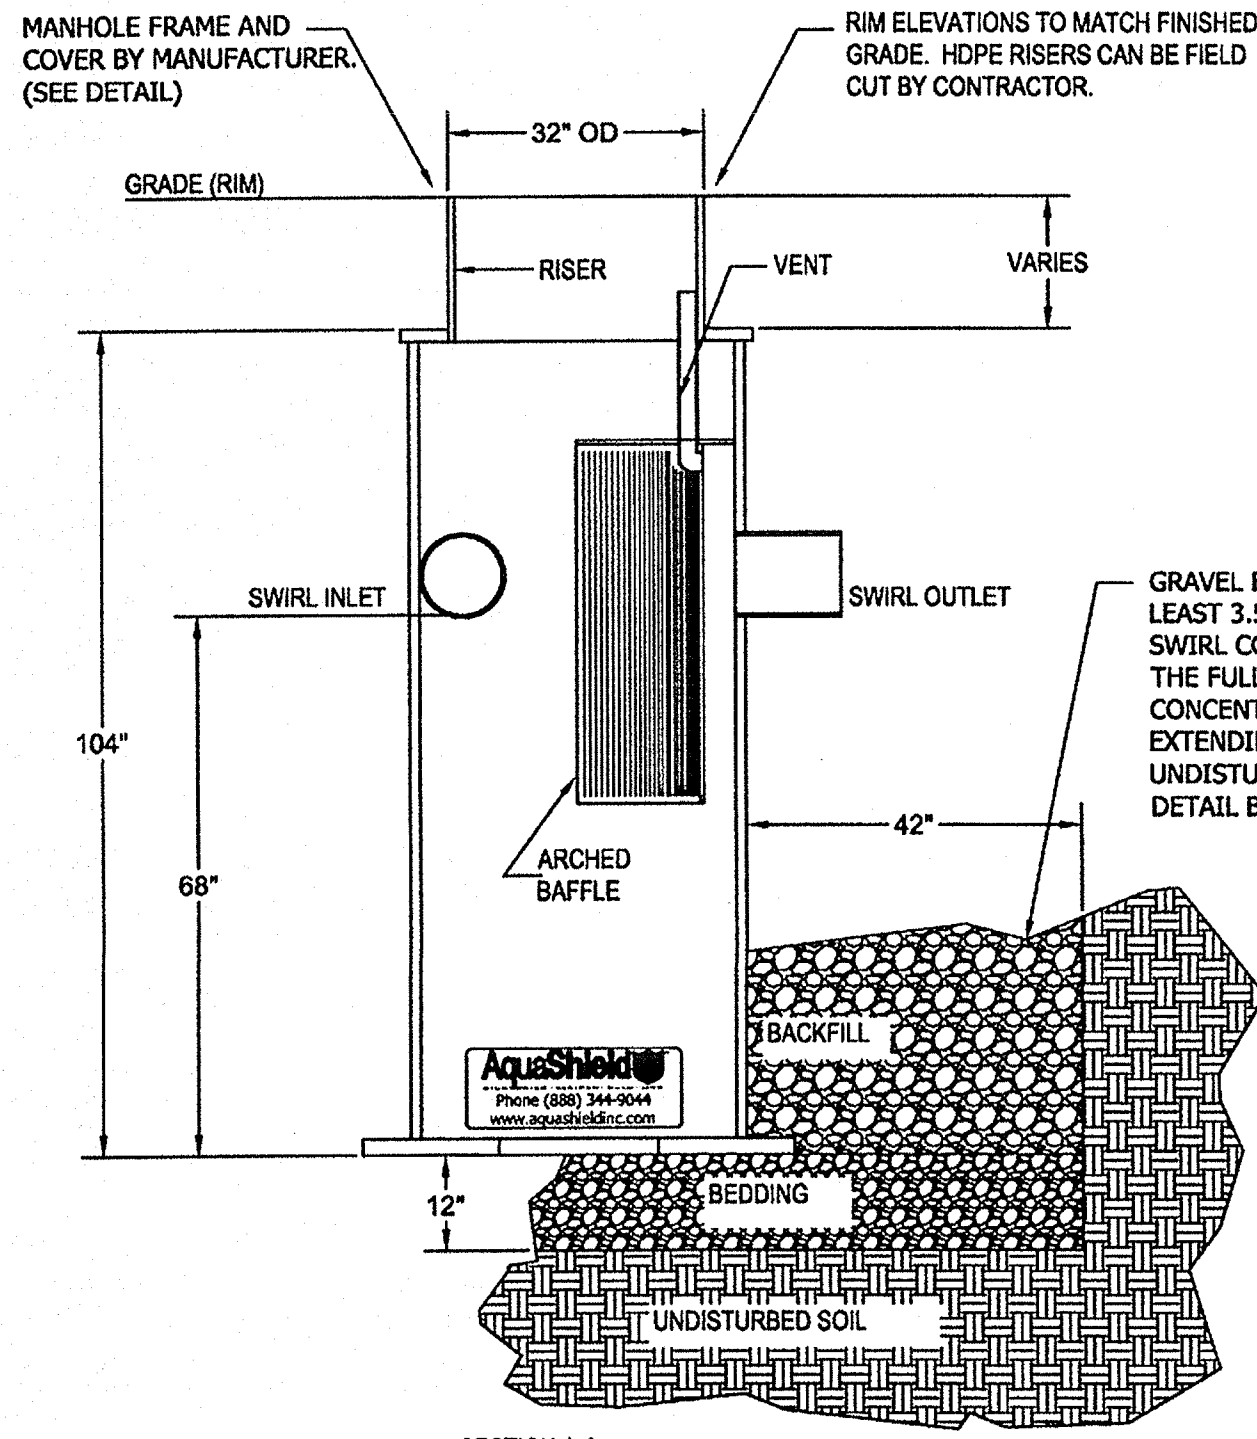


SECTION AA

AQUA-SWIRL CONCENTRATOR MODEL AS-3 OFF-LINE STANDARD DETAIL

SCALE: NTS

NOTES:

1. ALL PIPE SYSTEMS SHALL BE INSTALLED IN ACCORDANCE WITH ASTM D2321, "STANDARD PRACTICE FOR UNDERGROUND INSTALLATION OF THERMOPLASTIC PIPE FOR SEWERS AND OTHER GRAVITY FLOW APPLICATIONS", LATEST ADDITION
2. MEASURES SHOULD BE TAKEN TO PREVENT MIGRATION OF NATIVE FINES INTO BACKFILL MATERIAL, WHEN REQUIRED.
3. FOUNDATION: WHERE THE TRENCH BOTTOM IS UNSTABLE, THE CONTRACTOR SHALL EXCAVATE TO A DEPTH REQUIRED BY THE ENGINEER AND REPLACE WITH SUITABLE MATERIAL AS SPECIFIED BY THE ENGINEER, AS AN ALTERNATIVE AND AT THE DISCRETION OF THE DESIGN ENGINEER, THE TRENCH BOTTOM MAY BE STABILIZED USING A GEOTEXTILE MATERIAL.
4. BEDDING: SUITABLE MATERIAL SHALL BE CLASS I, II OR III. THE CONTRACTOR SHALL PROVIDE DOCUMENTATION FOR MATERIAL SPECIFICATION TO ENGINEER, UNLESS OTHERWISE NOTED BY THE ENGINEER, MINIMUM BEDDING THICKNESS SHALL BE 4" (100mm) FOR 4"-24" (100mm-600mm); 6" (150mm) FOR 30"-60" (750mm-900mm).
5. INITIAL BACKFILL: SUITABLE MATERIAL SHALL BE CLASS I, II OR III IN THE PIPE ZONE EXTENDING NOT LESS THAN 6" ABOVE CROWN OF PIPE. THE CONTRACTOR SHALL PROVIDE DOCUMENTATION FOR MATERIAL SPECIFICATION TO ENGINEER. MATERIAL SHALL BE INSTALLED AS REQUIRED IN ASTM D2321, LATEST EDITION.
6. MINIMUM COVER: MINIMUM COVER, H, IN NON-TRAFFIC APPLICATIONS (GRASS OR LANDSCAPE AREAS) IS 12" FROM THE TOP OF PIPE TO GROUND SURFACE. ADDITIONAL COVER MAY BE REQUIRED TO PREVENT FLOATION. FOR TRAFFIC APPLICATIONS, MINIMUM COVER, H, IS 12" UP TO 48" DIAMETER PIPE AND 24" OF COVER FOR 54"-60" DIAMETER PIPE, MEASURED FROM TOP OF PIPE TO BOTTOM OF FLEXIBLE PAVEMENT OR TO TOP OF RIGID PAVEMENT.

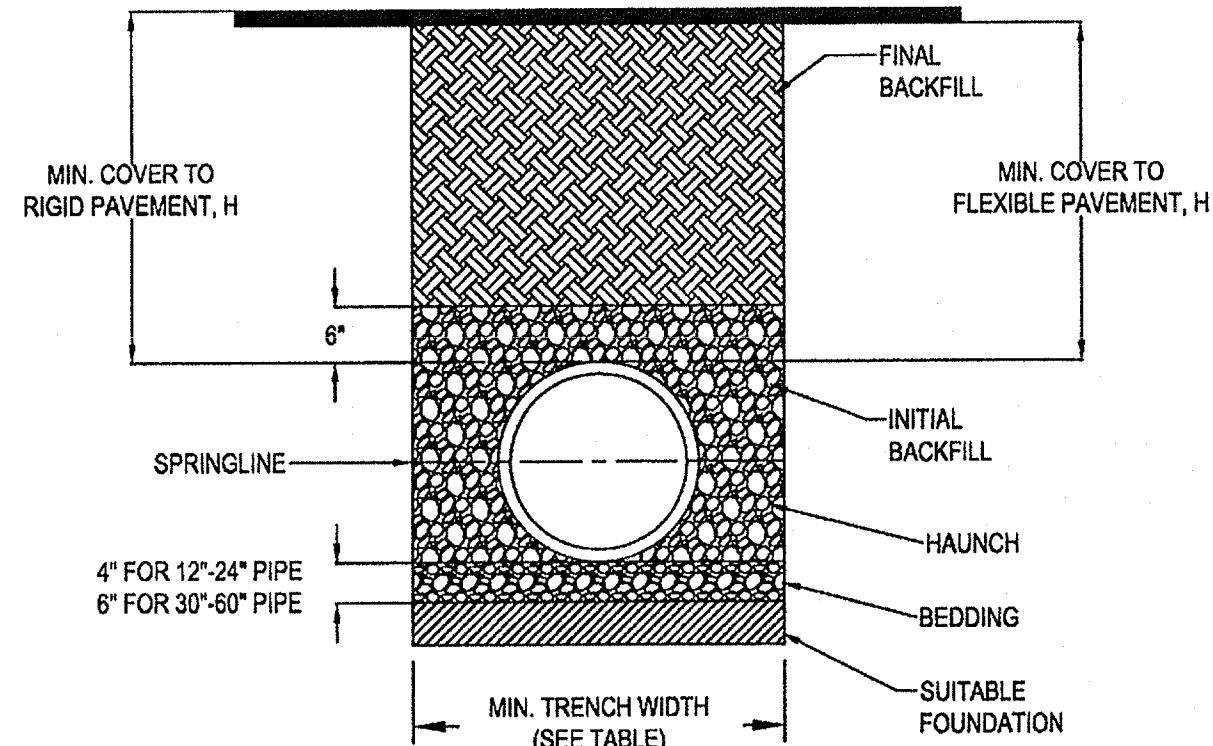

RECOMMENDED MINIMUM TRENCH WIDTHS

PIPE DIAM.	MIN. TRENCH WIDTH
4"	21"
6"	23"
8"	26"
10"	28"
12"	30"
15"	34"
18"	39"
24"	48"
30"	56"
36"	64"
42"	72"
48"	80"
54"	88"
60"	96"

MINIMUM RECOMMENDED COVER BASED ON VEHICLE LOADING CONDITIONS

PIPE DIAM.	SURFACE LIVE LOADING CONDITION	
	H-25	HEAVY CONSTRUCTION (75T AXLE LOAD) *
12" - 48"	12"	48"
54" - 60"	24"	60"

* VEHICLES IN EXCESS OF 75T MAY REQUIRE ADDITIONAL COVER

MINIMUM RECOMMENDED COVER BASED ON RAILWAY LOADING CONDITIONS

PIPE DIAM.	COOPER E-80**
UP TO 24"	24"
30"-36"	36"
42"-60"	48"


** COVER IS MEASURED FROM TOP OF PIPE TO BOTTOM OF RAILWAY TIE.

*** E-80 COVER REQUIREMENTS, ARE ONLY APPLICABLE TO ASTM F 2306 PIPE.

PLASTIC PIPE (PVC & HDPE) TRENCH DETAIL


SCALE: NTS

BOLLARDS SHALL BE PLACED AROUND ACCESS RISER(S) IN NON-TRAFFIC AREAS TO PREVENT INADVERTENT LOADING BY MAINTENANCE VEHICLES.

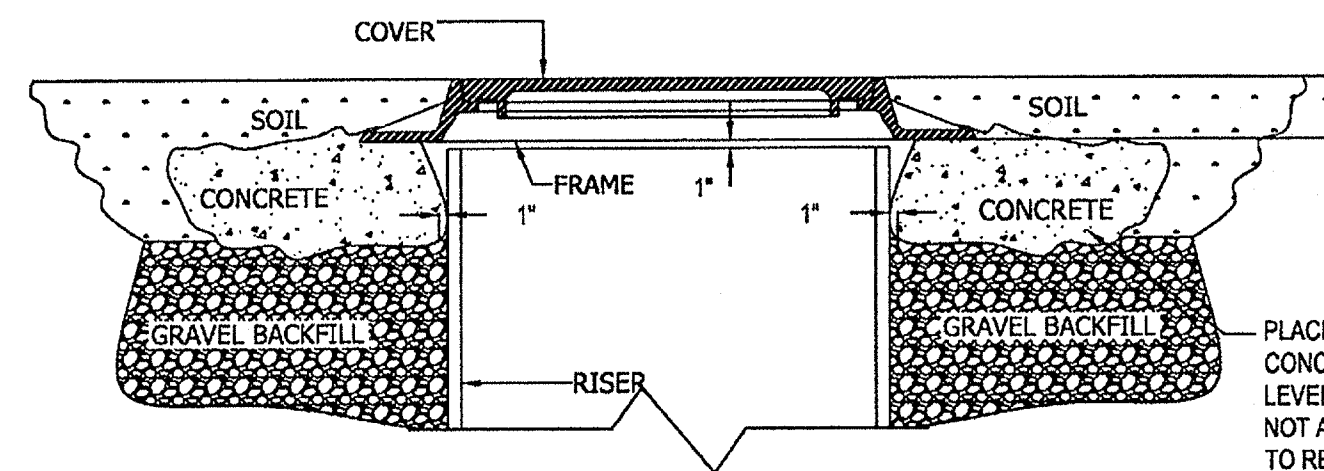


MANHOLE FRAME & COVER DETAIL FOR NON-TRAFFIC AREAS ONLY

SCALE: NTS

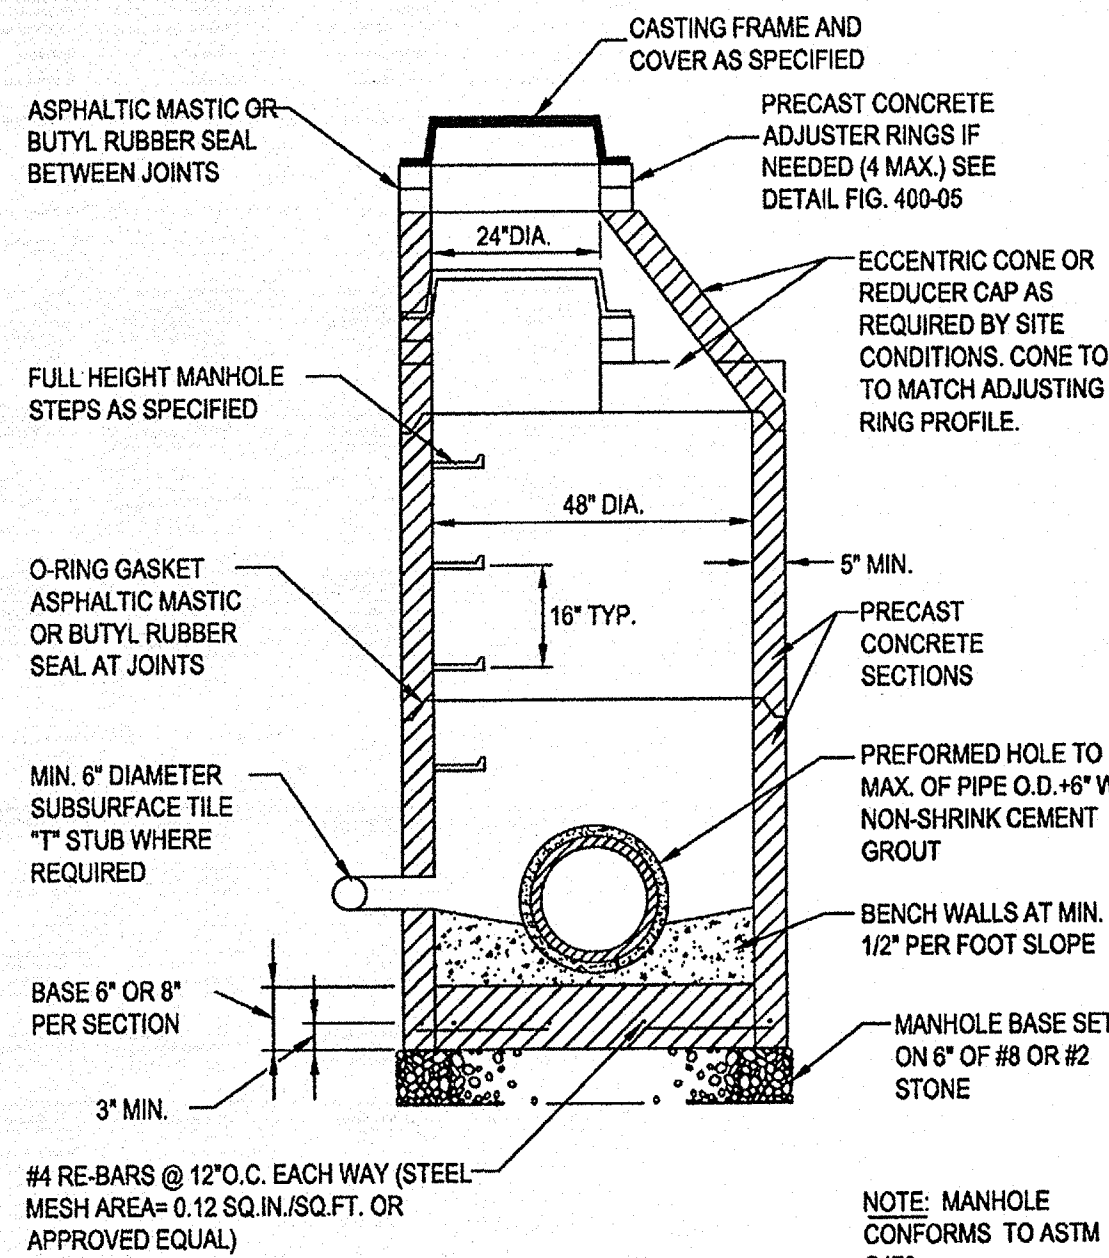

STANDARD MANHOLE FOR PIPE SIZES 12" THRU 24"


SCALE: NTS

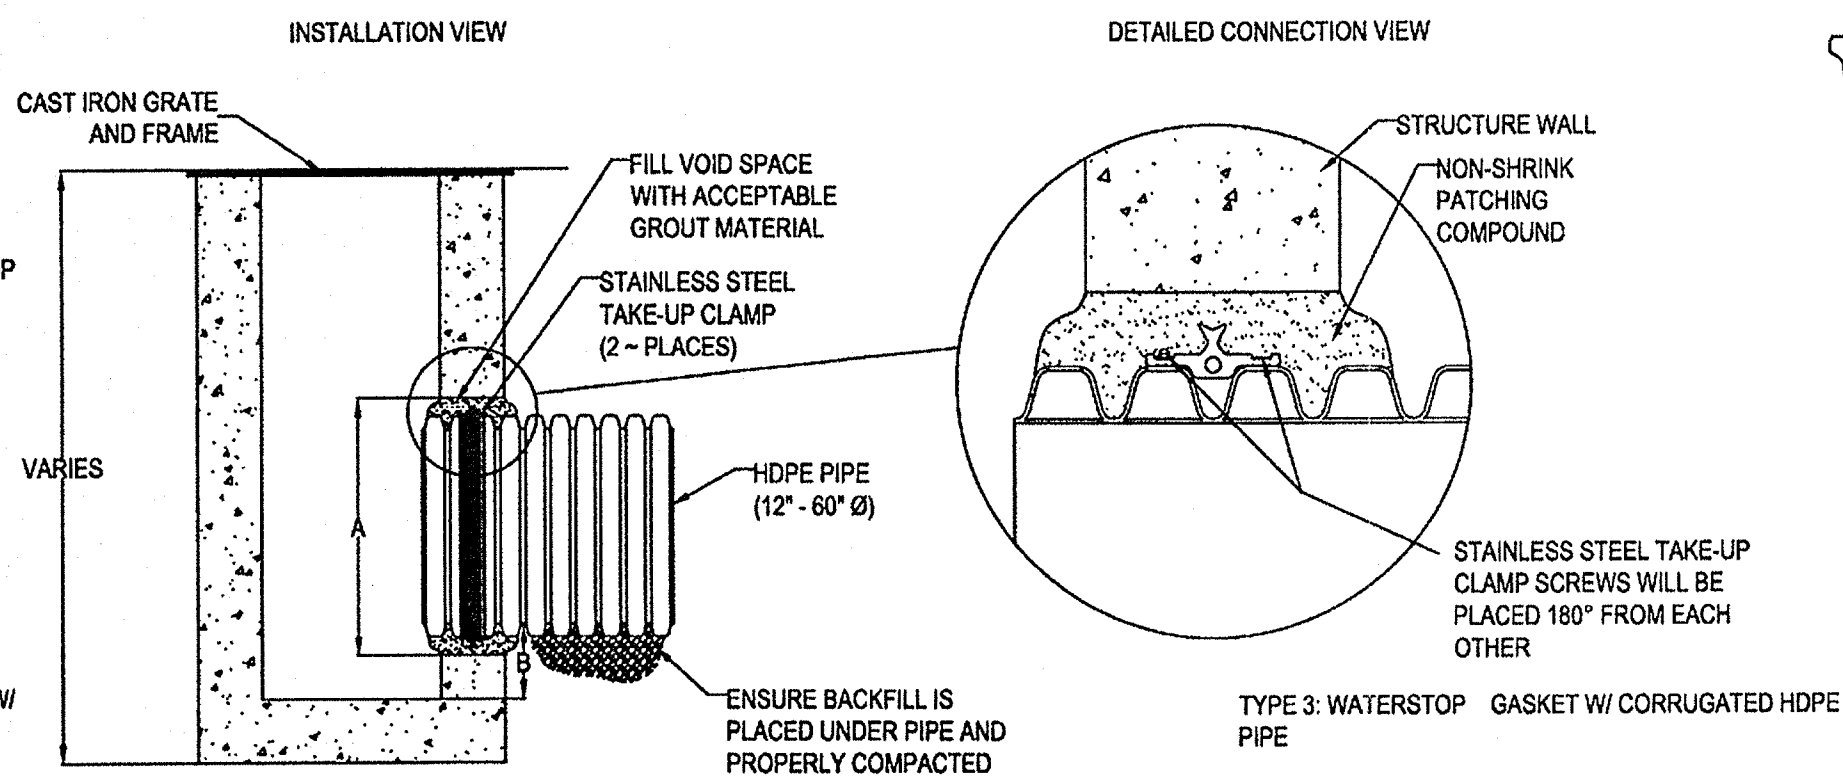

PIPE SIZE (IN)	PIPE OD (IN)		*A* MIN. HOLE Ø (IN)	*B* MIN. DISTANCE PIPE INVERT TO STRUCTURE INVERT (IN)
	A-PROFILE	H-PROFILE		
12	14.5	14.2	19.50	3.7
15	17.6	17.8	23.00	4.0
18	21.2	21.5	26.50	4.2
24	27.8	28.4	33.25	4.5
30	35.1	35.5	40.50	5.2
36	41.1	41.4	47.00	5.5
42	47.7	48.0	53.00	5.7
48	53.6	54.0	59.00	5.7
60	66.3	67.3	72.00	6.4

MANHOLE CONNECTION DETAIL


SCALE: NTS

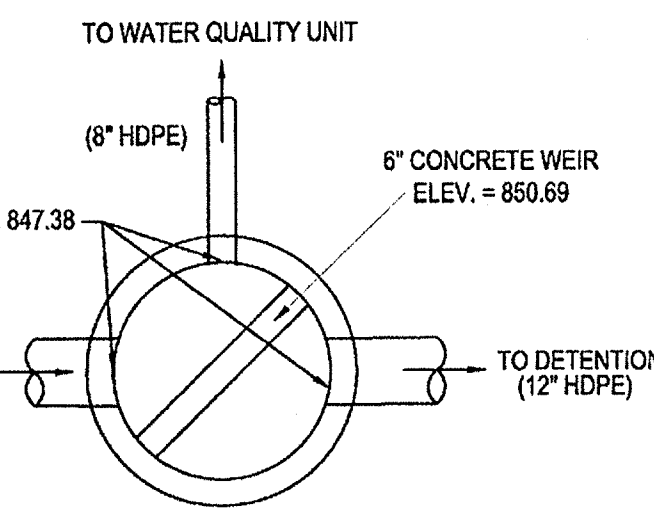

NOTE: BYPASS WEIR SHALL BE CONSTRUCTED AT THE PRECAST PLANT ACCORDING TO THE DESIGNATED ELEVATION. CAST-IN-PLACE WEIR SHALL NOT BE ALLOWED.

BYPASS STRUCTURE

SCALE: NTS

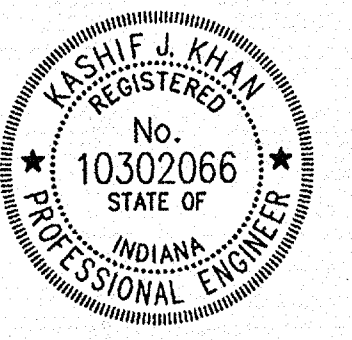


Kashif J. Khan

No.	Revision/Issue	Date


INFRASTRUCTURE ENGINEERING, INC.
 2601 FORTUNE CIRCLE EAST,
 SUITE 201C
 INDIANAPOLIS, IN 46241
 PHONE: 317.243.9800
 info@infrastructure-eng.com

METROPOLITAN SCHOOL DISTRICT OF
 LAWRENCE TOWNSHIP
 CONSTRUCTION PLANS
 LAWRENCE CENTRAL HIGH SCHOOL
 ATHLETIC FIELD IMPROVEMENTS
 7300 East 56th Street
 Indianapolis, IN 46226


Sheet Name STANDARD DETAILS	
Project 08-2052	Sheet Number
Date APRIL 25, 2008	S-503
Scale AS NOTED	

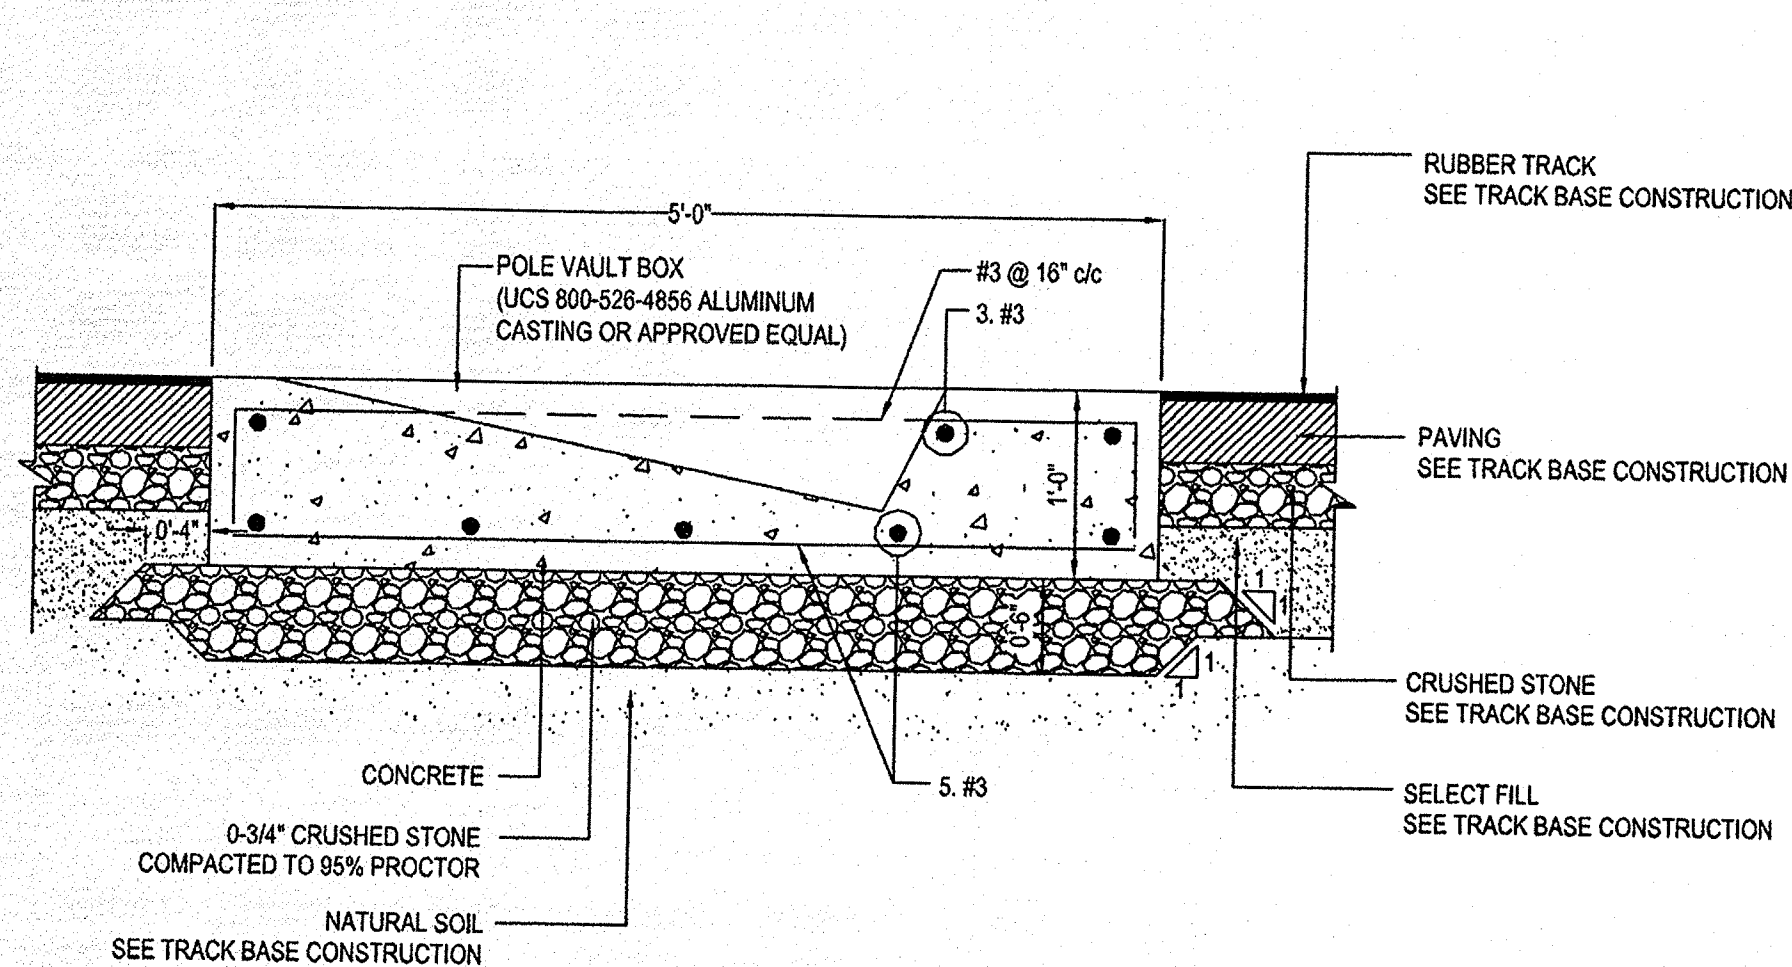

SECTION A-A
SCALE: NTS

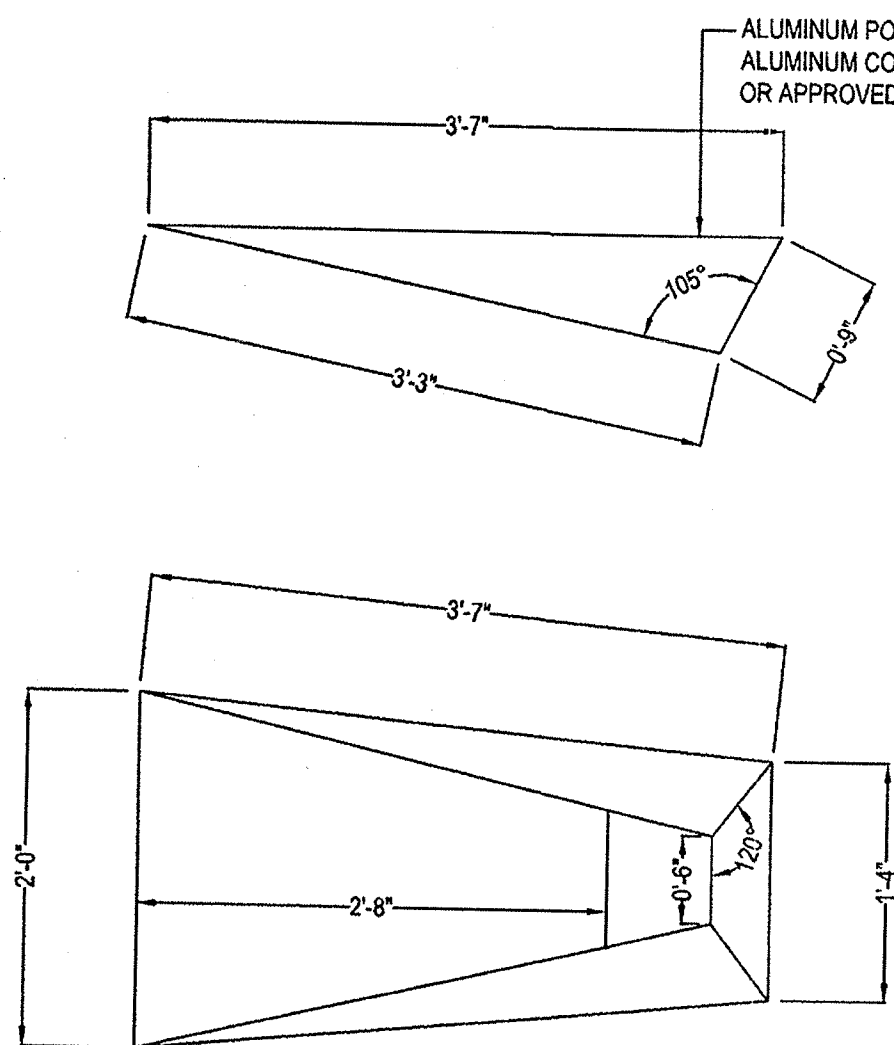

POLE VAULT BOX
SCALE: NTS

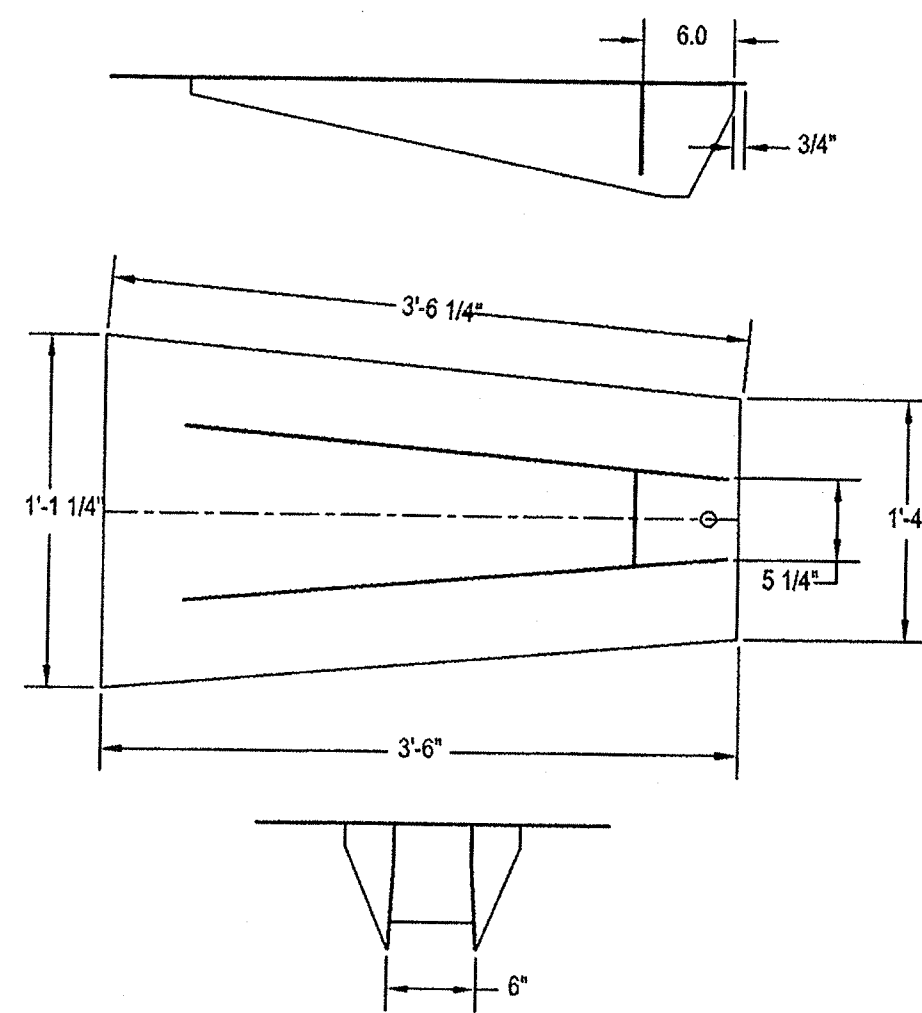

POLE VAULT BOX COVER
SCALE: NTS


ALL CONCRETE SHALL BE 3500 PSI AT 28 DAYS UNLESS NOTED OTHERWISE ON THE DRAWINGS OR IN THE SPECIFICATIONS. ALL REINFORCING STEEL SHOWN INTERMEDIATE GRADE.

MAXIMUM SLOPE OF CONCRETE SHALL BE 4" UNLESS OTHERWISE NOTED OR APPROVED BY THE ENGINEER. ADMIXTURES MAY BE USED IN CONCRETE, BUT ADVICE AS TO TYPE, QUANTITY AND PURPOSE MUST BE GIVEN TO THE ENGINEER PRIOR TO PLACING ANY CONCRETE. MAX. WATER/CEMENT MATERIAL RATIO = 0.55


A VIBRATOR IS TO BE USED FOR ALL STRUCTURAL CONCRETE AND FOR ALL CONCRETE WHICH WILL REMAIN EXPOSED. THIS INCLUDES ALL FOUNDATIONS AND FONDATION WALLS.

PROVIDE MOIST CURING FOR ALL CONCRETE ON GRADE FOR MINIMUM OF 7 (SEVEN) DAYS AFTER PLACING CONCRETE. ALTERNATIVELY, A CURE/SEAL COMPOUND MAY BE USED IF PRIOR APPROVAL IS SECURED FROM THE ARCHITECT AND ENGINEER.


IF MOIST CURING OR CURE SEAL COMPOUND IS NOT APPLIED AS DIRECTED, THE CONTRACTOR SHALL BE HELD RESPONSIBLE FOR ANY AND ALL FAILURES OF THE SLAB REGARDLESS OF HOW THESE FAILURES MAY BE CAUSED.

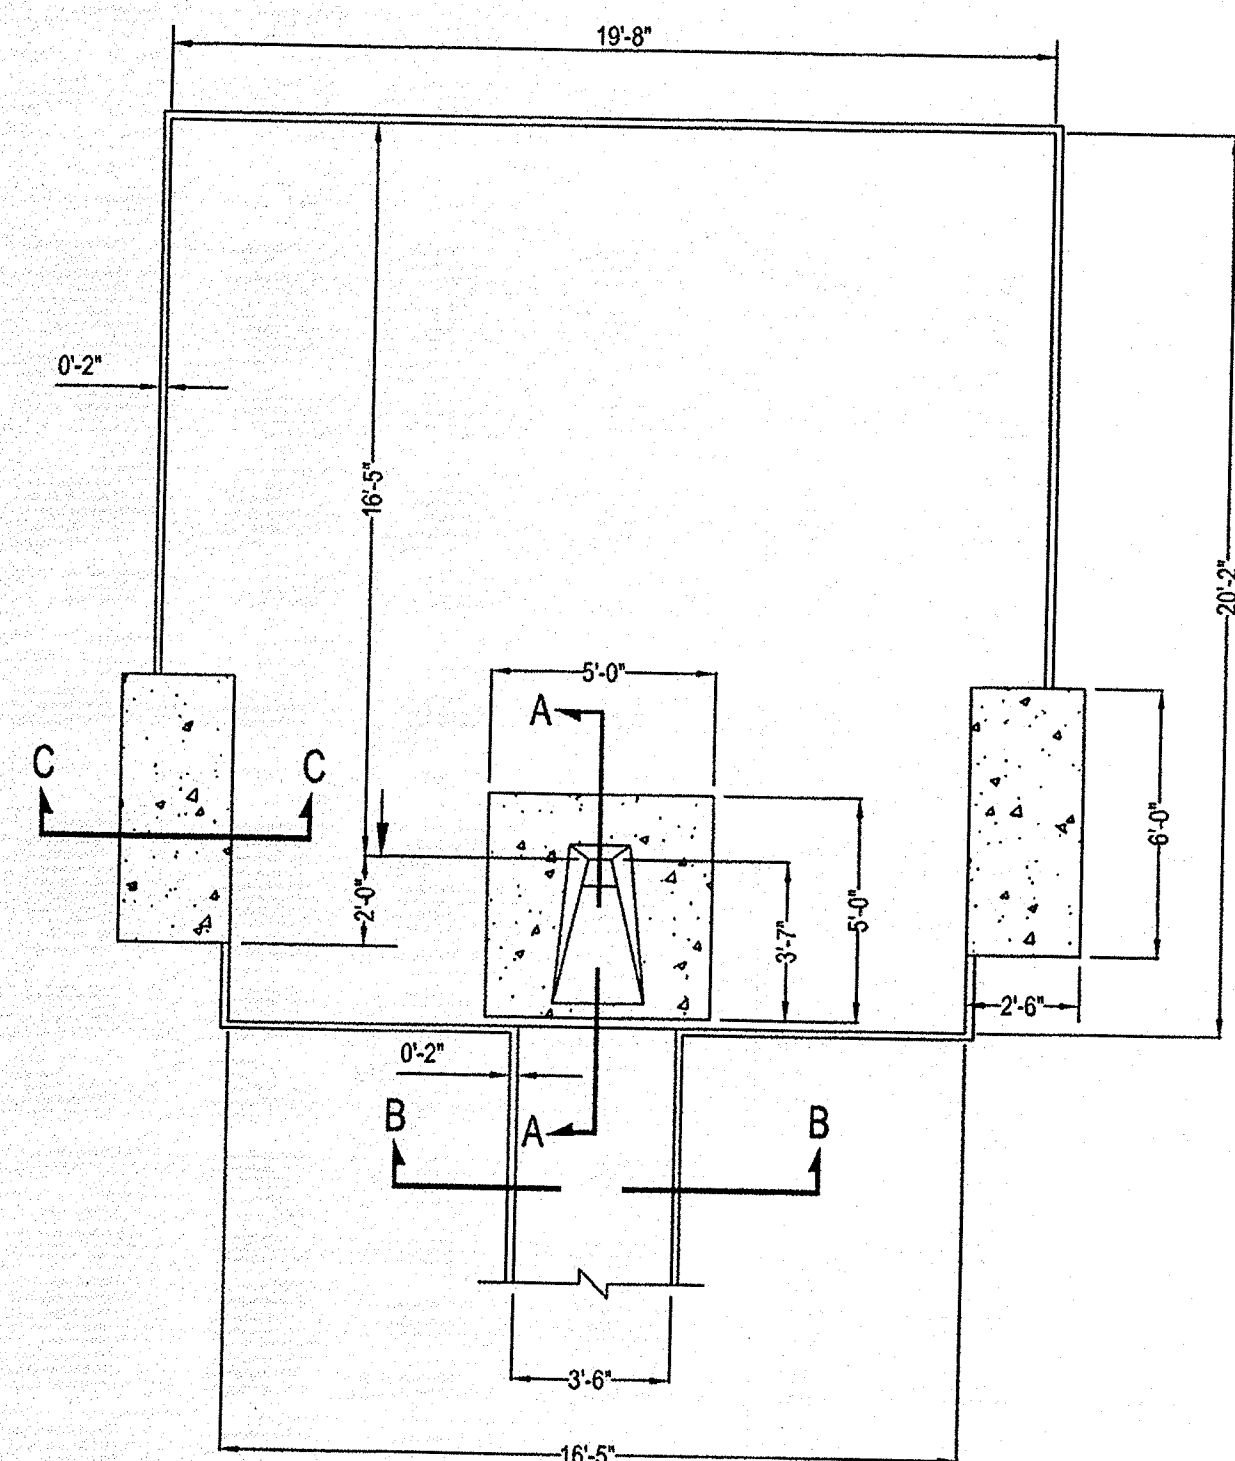


SECTION B-B
SCALE: NTS

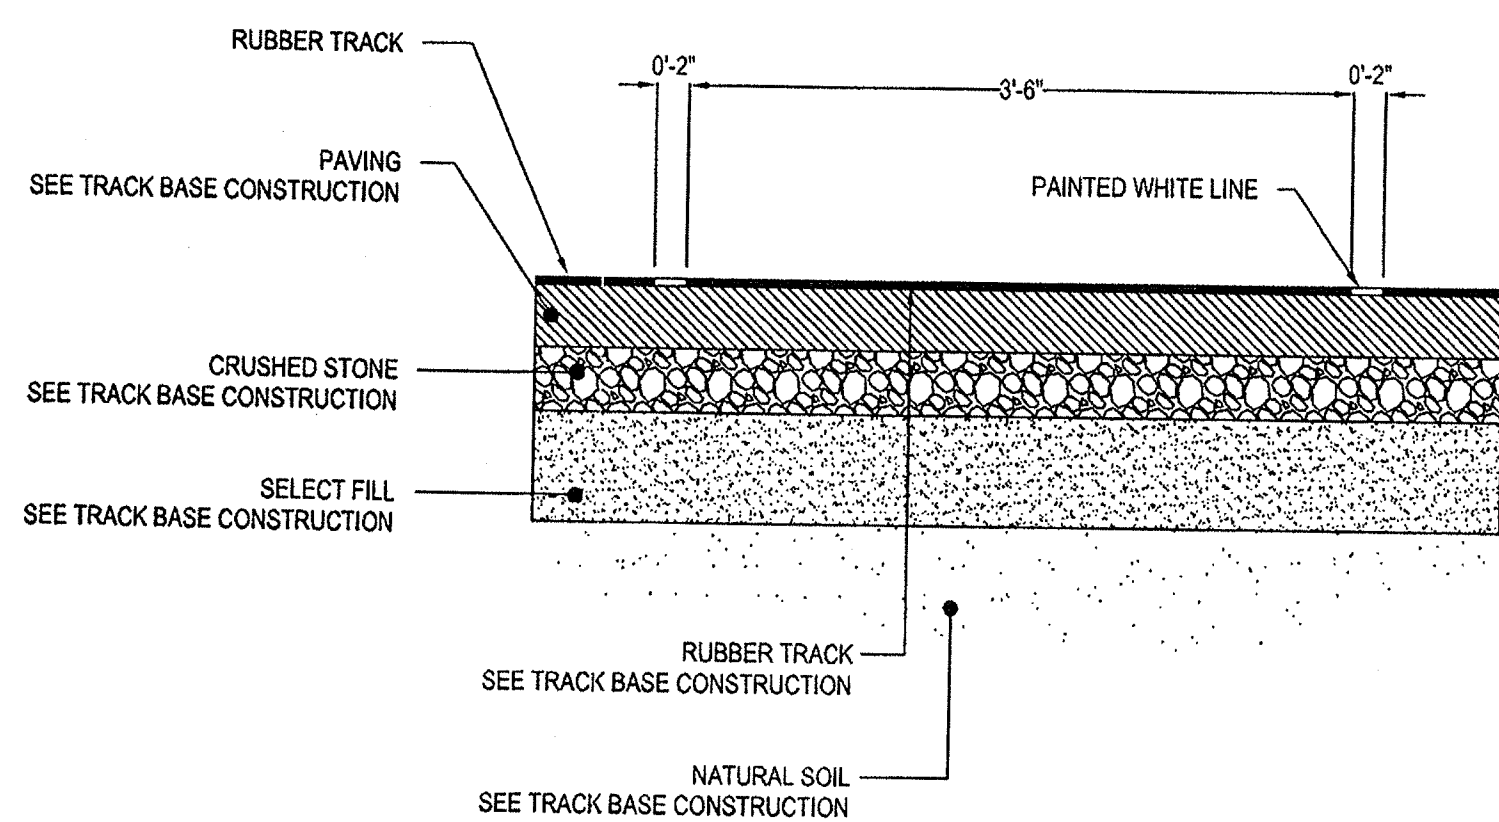


SECTION C-C
SCALE: NTS

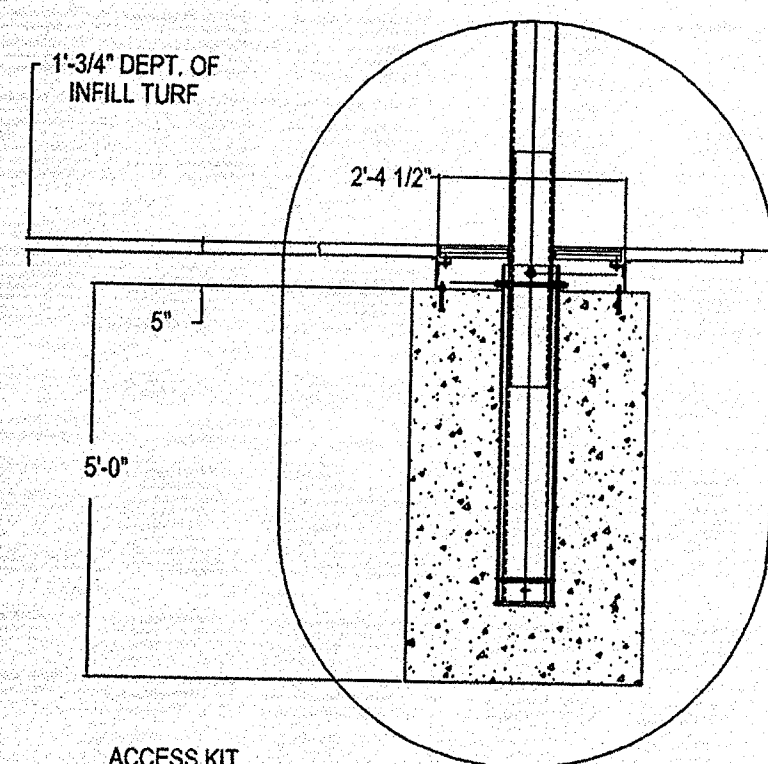


POLE VAULT DETAIL
SCALE: NTS

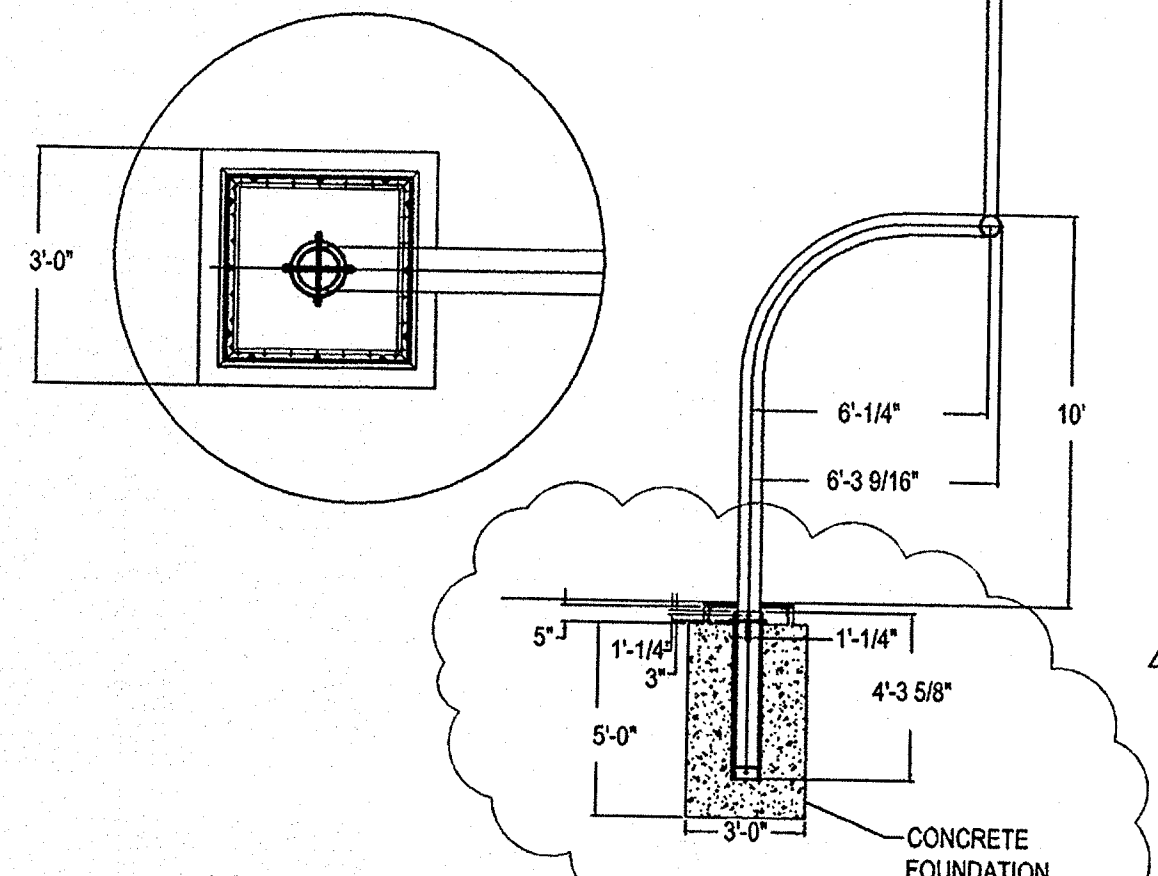

GOAL POST DETAILS
SCALE: NTS

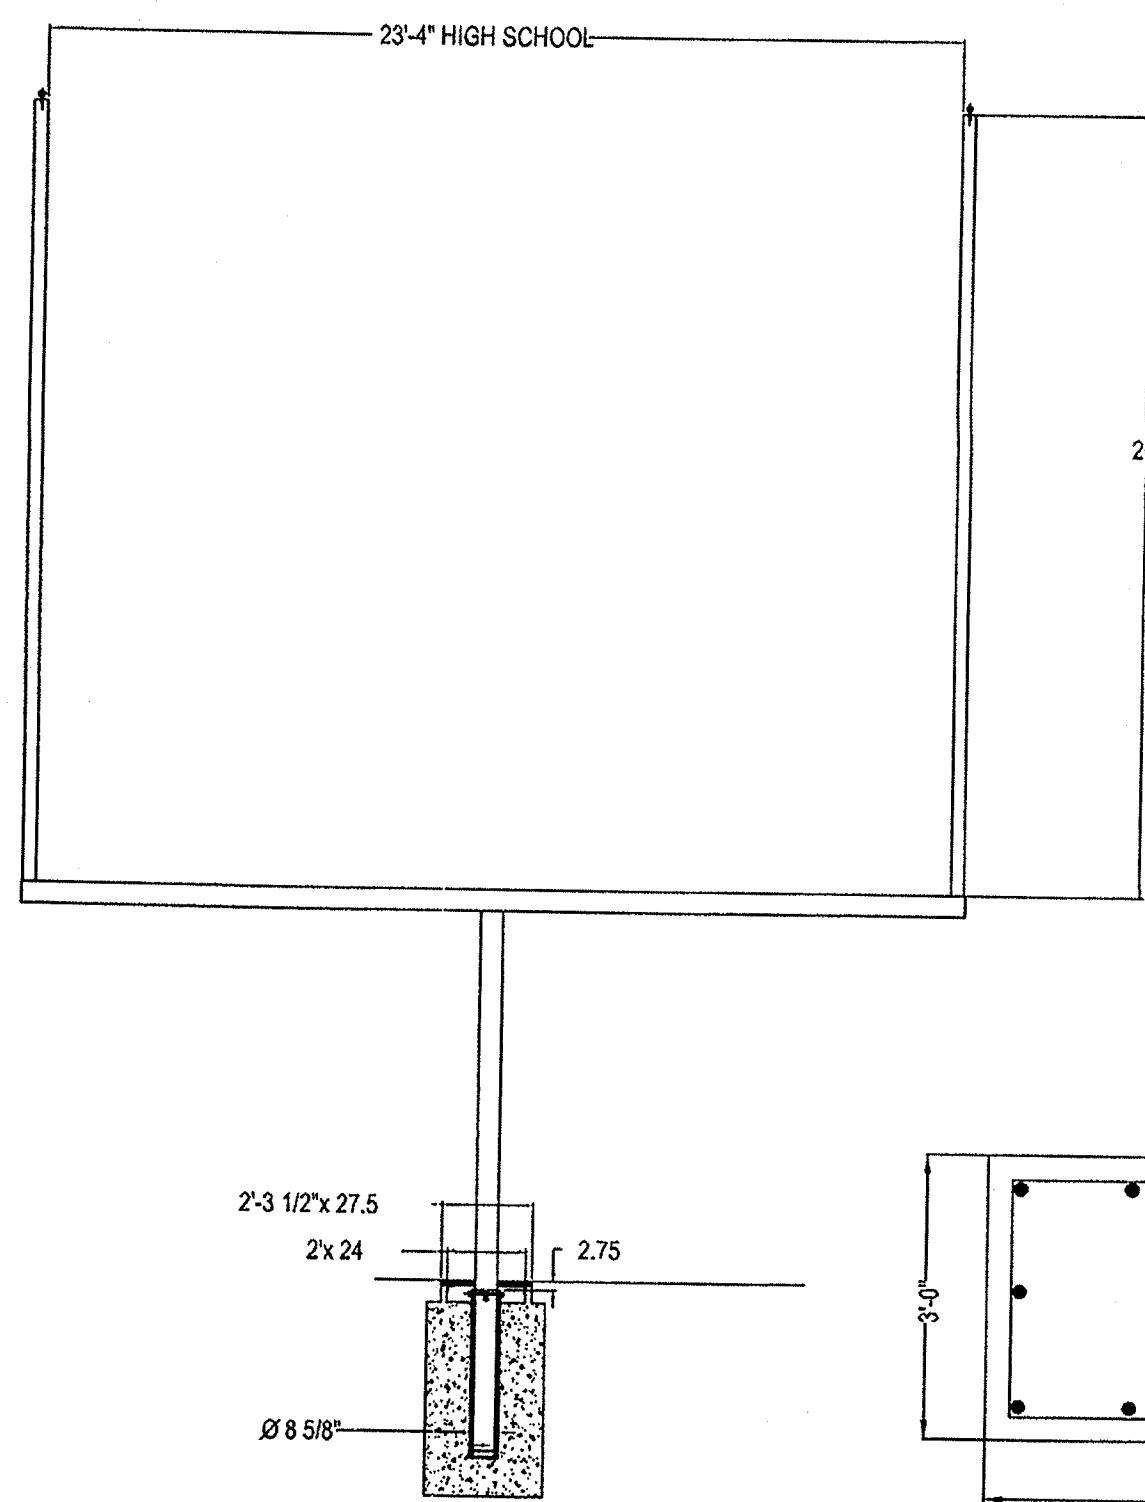


PLAYCLOCK FOUNDATION DETAIL
SCALE: NTS

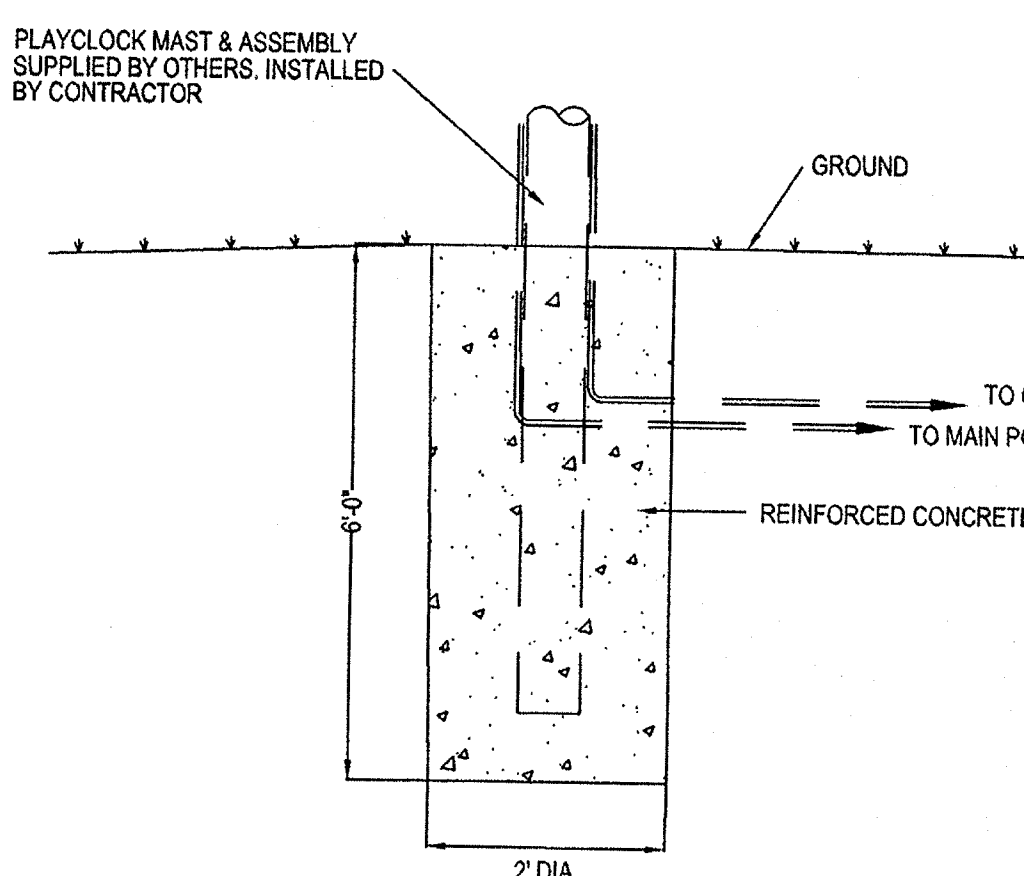

PLAYCLOCK FOUNDATION X-SECTION
SCALE: NTS

GENERAL NOTES:
SEE SHEET S-501 FOR TRACK BASE CONSTRUCTION DETAIL.

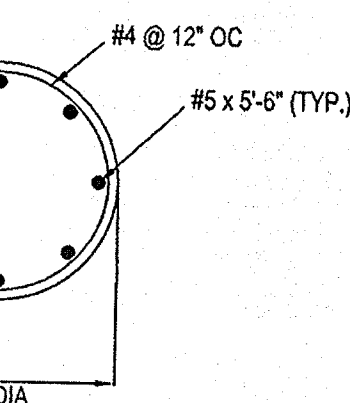

GOAL POST FOUNDATION X-SECTION
SCALE: NTS

HOLEY MOLEY SAYS
"DON'T DIG BLIND"
CALL TOLL FREE
"IT'S THE LAW"
CALL 2 WORKING DAYS BEFORE YOU DIG
1-800-382-5544
CALL TOLL FREE
PER INDIANA STATE LAW 35-39-1501,
IF IN VIOLATION OF THE LAW TO EXCAVATE
WITHOUT NOTIFYING THE UNDERGROUND
LOCATION SERVICE TWO (2) WORKING
DAYS BEFORE COMMENCING WORK.




K. Khan

No.	CHANGES TO GOAL POST DIMENSIONS	Revision/Issue	Date
1			5/9/08





INFRASTRUCTURE ENGINEERING, INC.
2801 FORTUNE CIRCLE EAST,
SUITE 201C
INDIANAPOLIS, IN 46241
PHONE: 317.243.9800
info@infrastructure-eng.com

METROPOLITAN SCHOOL DISTRICT OF
LAWRENCE TOWNSHIP
CONSTRUCTION PLANS
LAWRENCE CENTRAL HIGH SCHOOL
ATHLETIC FIELD IMPROVEMENTS
7300 East 56th Street
Indianapolis, IN 46226

Sheet Name	Project	Sheet Number
STANDARD DETAILS	08-2052	
Date	APRIL 25, 2008	
Scale	AS NOTED	S-504

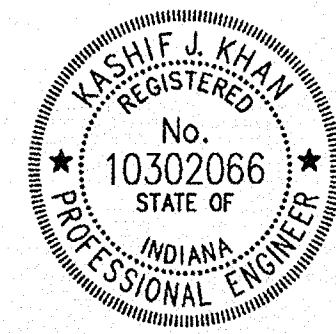

KASHIF J. KHAN
REGISTERED
No. 10302066
STATE OF INDIANA
PROFESSIONAL ENGINEER

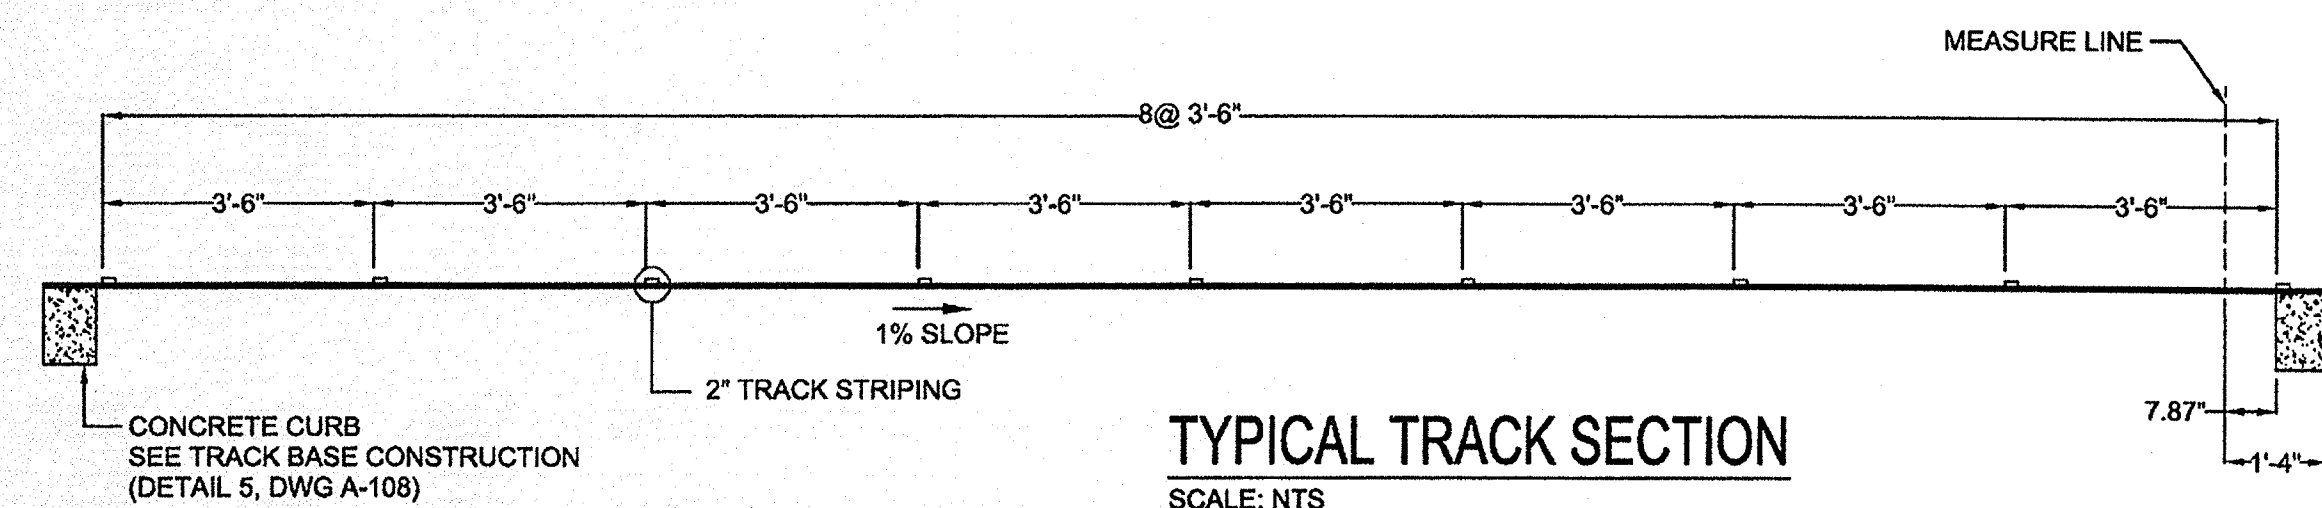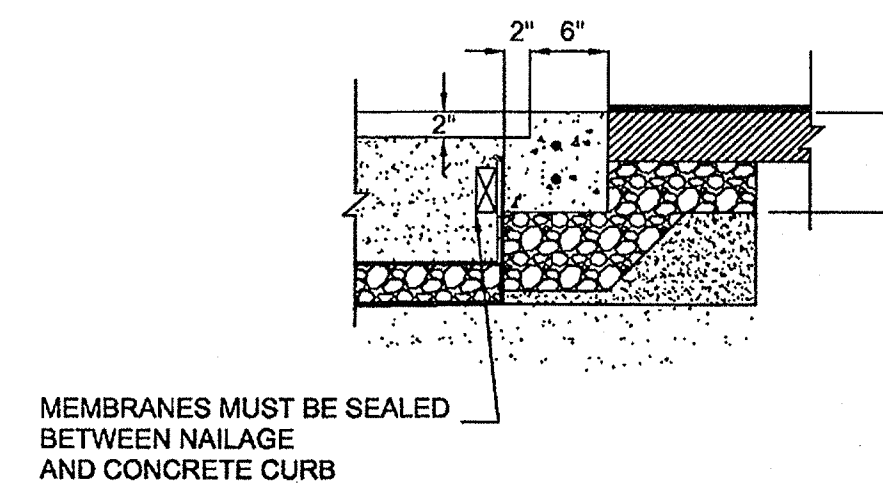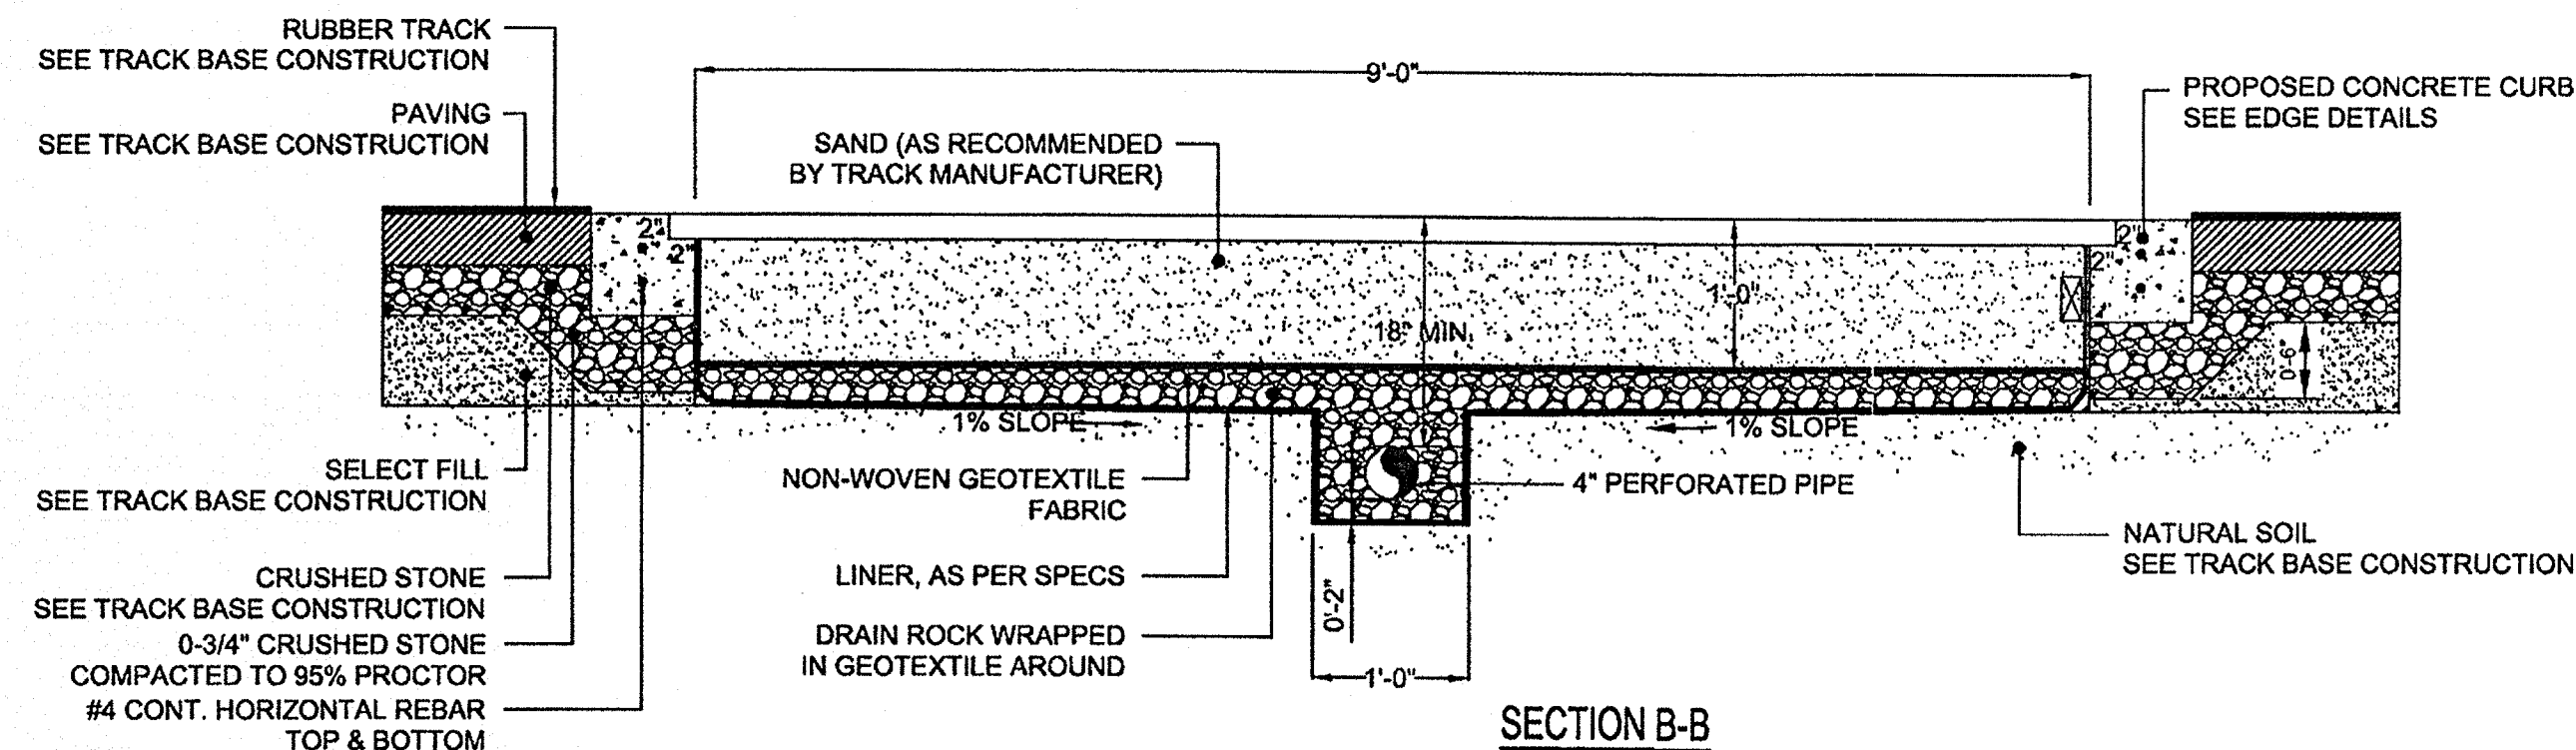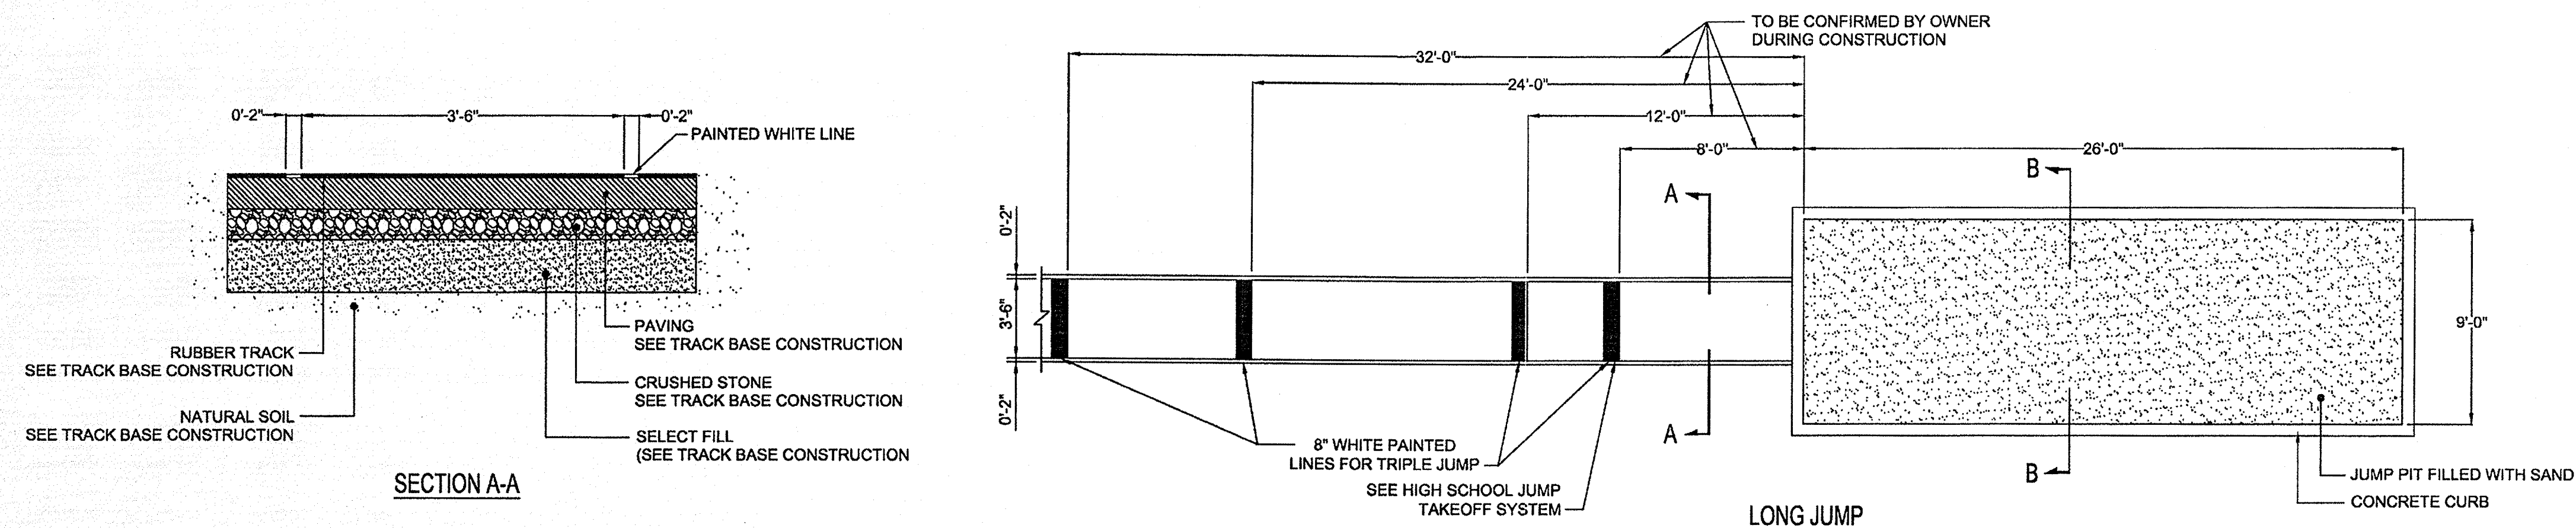


PARTS LIST			
ITEM	PT. NO.	DESCRIPTION	QTY.
1	519-B121-00	FOUNDATION TRAY	(1)
2	519-B1021-10	BOARD UNDERSTRUCTURE	(1)
3	519-B121-10A	TAKE-OFF BOARD	(1)
4	---	ADJUSTING LEVELING SCREW (3/8-16 X 1 1/2)	(12)
5	---	NUTS (3/8-16) FOR LEVELING SCREW	(8)
6	---	SCREW, WOOD, FLAT HD. #6 X 1 1/2	(6)
7	---	BLANKING LID	(1)

UCS HIGH SCHOOL LONG JUMP/TRIPLE JUMP TAKEOFF SYSTEM INSTALLATION



INSTRUCTIONS NOTE:

A PVC DRAIN SHOULD BE SUPPLIED AND INSTALLED BY THE CONTRACTOR WHEN INSTALLING THE FOUNDATION TRAY.

1. BASE OF FOUNDATION TRAY SHOULD REST ON A LEVEL CONCRETE SURFACE WHICH IS LOCATED 127mm BELOW TOP OF BASE SURFACE AND FOUNDATION TRAY.
2. LIP OF FOUNDATION TRAY SHOULD BE FLUSH WITH BASE SURFACE CHECK LEVEL AND POUR CONCRETE AROUND TRAY. (FIG. 1)
3. BLANKING LID SHOULD BE PERPARED TO ACCEPT SYNTHETIC SURFACE. (ADHESIVE, ACID ETCH, OR SAND TO PREP SURFACE)
4. PLACE BLANKING LID INTO FOUNDATION TRAY AND ADJUST LEVELING SCREWS UNTILL LID IS LEVEL AND FLUSH WITH TOP EDGES OF FOUNDATION
5. INSERT SMALL 2mm DIA. ROD IN EACH OF THE FOUR CORNERS OF BLANKING LID TO LOCATE CUTTING LINES. RODS MUST BE VERTICAL AND EXTEND ABOVE TOP OF SYNTHETIC SURFACE.
6. INSERT LARGE 19mm ROD IN THE TWO LIFTING HOLES. THE RODS MUST EXTEND ABOVE TOP OF SYNTHETIC SURFACE.
7. POUR SYNTHETIC SURFACE.
8. AFTER THE SURFACE HAS SET USE THE SMALL RODS AS A GUIDE FOR STRAIGHT EDGE AND CUT A RECTANGULAR SHAPE TO MATCH THE BLANKING BOARD. USE A VERY SHARP BLADE TO ASSURE A CLEAN CUT. (FIG. 4)
9. REMOVE ALL RODS SO THAT THE BLANKING LID MAY BE LIFTED TO INSTALL THE TAKE-OFF BOARD UNDERSTRUCTURE.

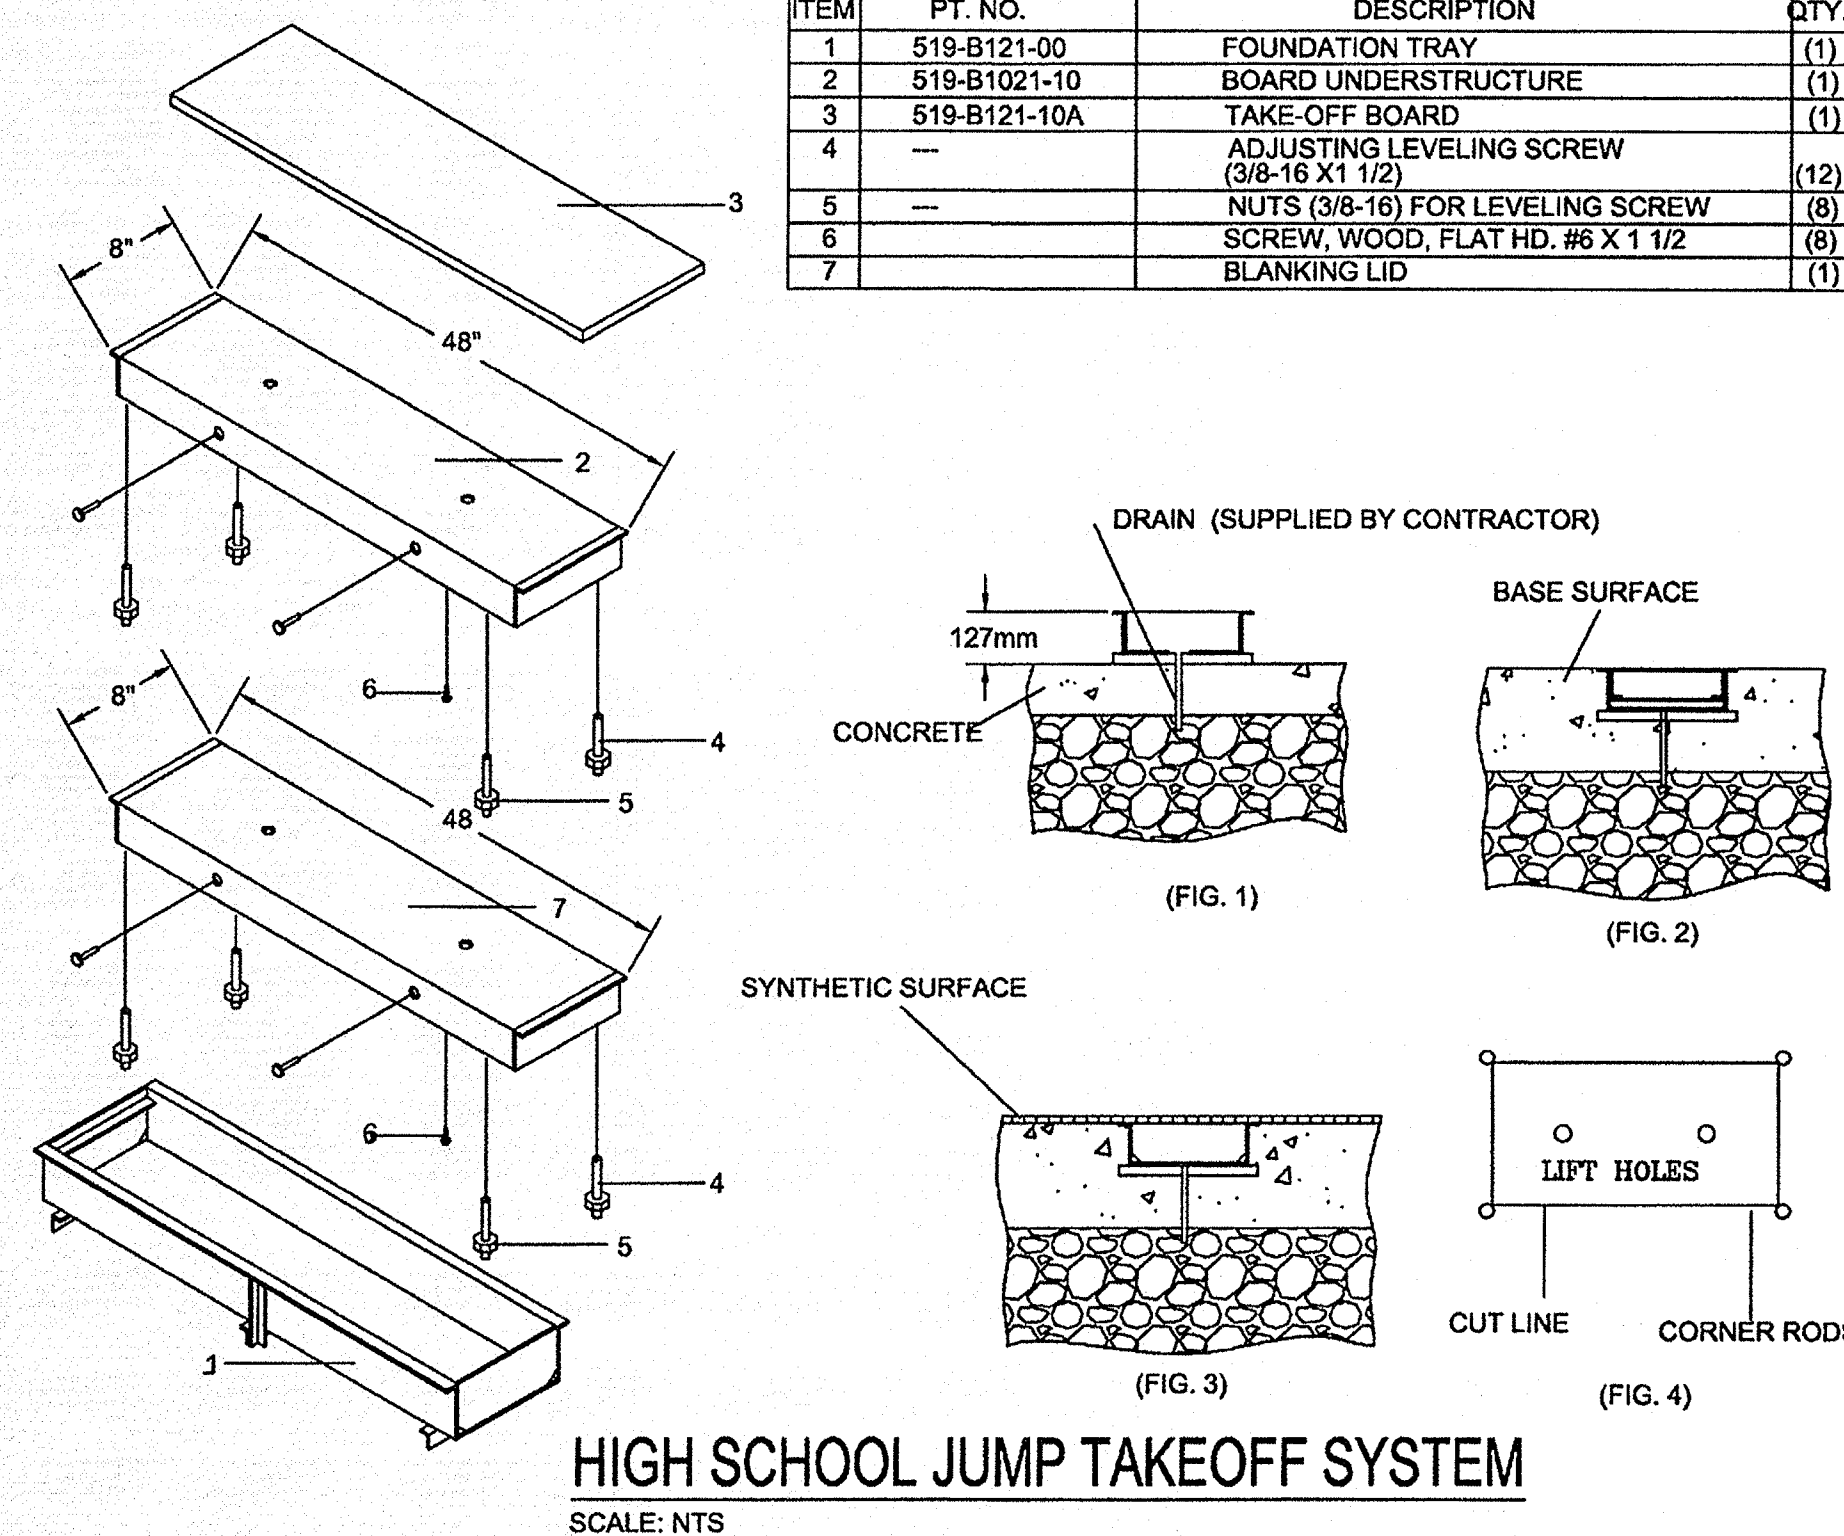

CONSTRUCTED OF 9 1/2" X 1 3/4" X 1/8" ALUMINUM PLANKING, CROSS BRACED WITH 3/16" X 2 1/2" ALUMINUM FLAT BAR, AND FRAMED WITH 1 1/2" X 2 3/8" X 3/16" ALUMINUM ANGLE.

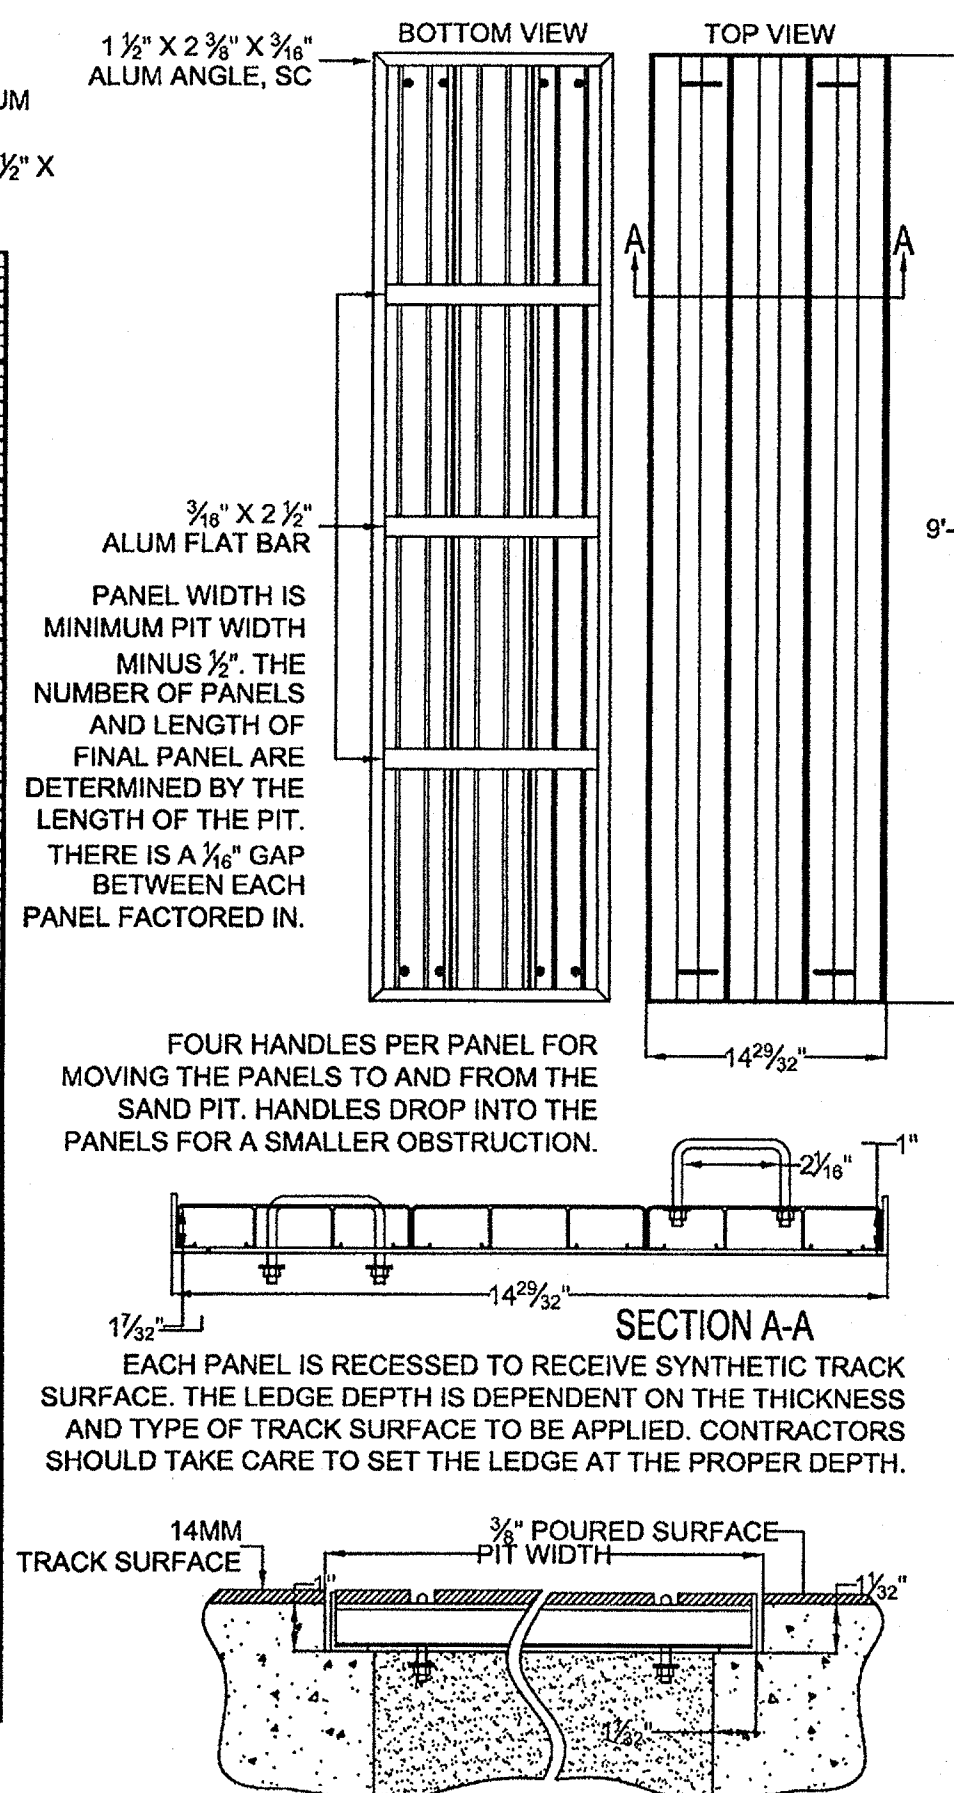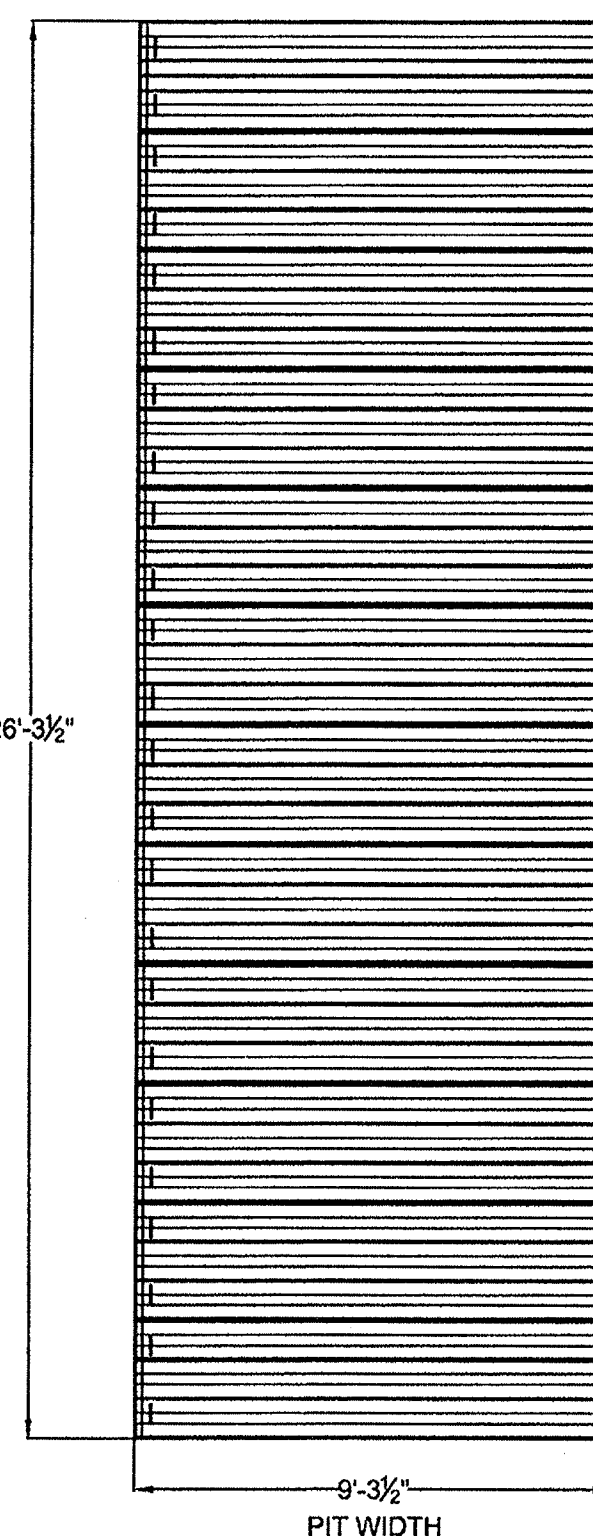

No.	Revision/Issue	Date

INFRASTRUCTURE ENGINEERING, INC.
2601 FORTUNE CIRCLE EAST,
SUITE 201C
INDIANAPOLIS, IN 46241
PHONE: 317.243.9800
info@infrastructure-eng.com

METROPOLITAN SCHOOL DISTRICT OF
LAWRENCE TOWNSHIP

CONSTRUCTION PLANS
LAWRENCE CENTRAL HIGH SCHOOL
ATHLETIC FIELD IMPROVEMENTS

7300 East 56th Street
Indianapolis, IN 46226

STANDARD DETAILS		
Project	08-2052	Sheet Number
Date	APRIL 25, 2008	S-505
Scale	AS NOTED	

SEAGroup
Land Surveyors

433 West Carmel Drive Phone: 317.844.3333
Carmel, IN 46032 Fax: 317.844.3383
www.SEAGroupLLC.com

LAWRENCE TOWNSHIP, MARION COUNTY

Attn: CHRIS LONG
CLIENT ADDRESS
CITY STATE ZIP
PHONE NUMBER
FAX NUMBER

[illegible]

DESTING CHARD PAL
 DESTING WEA-THE FORCE
 DESTING WEA-THE FORCE
 GAG = UNDERSTANDING GAS LINES
 CATV = UNDERSTANDING CAT TELEPHON LINES
 WTR = UNDERSTANDING WATER LINES
 STN = UNDERSTANDING STATION CHAIRS
 SW = UNDERSTANDING SWEATY SWEAT
 FLOP = UNDERSTANDING FLOOR-OPTIC
 UGT = UNDERSTANDING UPLIFTHANE
 OHE = UNDERSTANDING OVERTHE
 OHE = OVERHEAD ELECTRIC
 OHT = UNDERSTANDING OVERTHE
 OHT = UNDERSTANDING OVERTHE
 TRAF = UNDERSTANDING TRAFFIC LINES
 IRR = UNDERSTANDING IRRIGATION LINES
 IRR = ROOTS OF WAX (AS NOTED)
 OVERHEARS AS NOTED
 BSL = BUILDING STRUCK LINE
 BSL (AS NOTED)
 RAIL CUTE LINES (AS NOTED)
 SBAK RAIL CUTE SBAK LINE (AS NOTED)
 DESTING CHARD CURE (AS NOTED)
 CHORDS = UNDERSTANDING CHORDS
 CHORDS = UNDERSTANDING CHORDS
 TOB = TOP OF BARK
 TOB = TOP OF SHAPE

 DESTING LINES


C = CALCULATED BEARING AND DIAGONAL
 M = MEASURED BEARING AND DIAGONAL

VICINITY MAP - NOT TO SCALE

Reference #: 08-2052

Sheet Number :

1 of 1

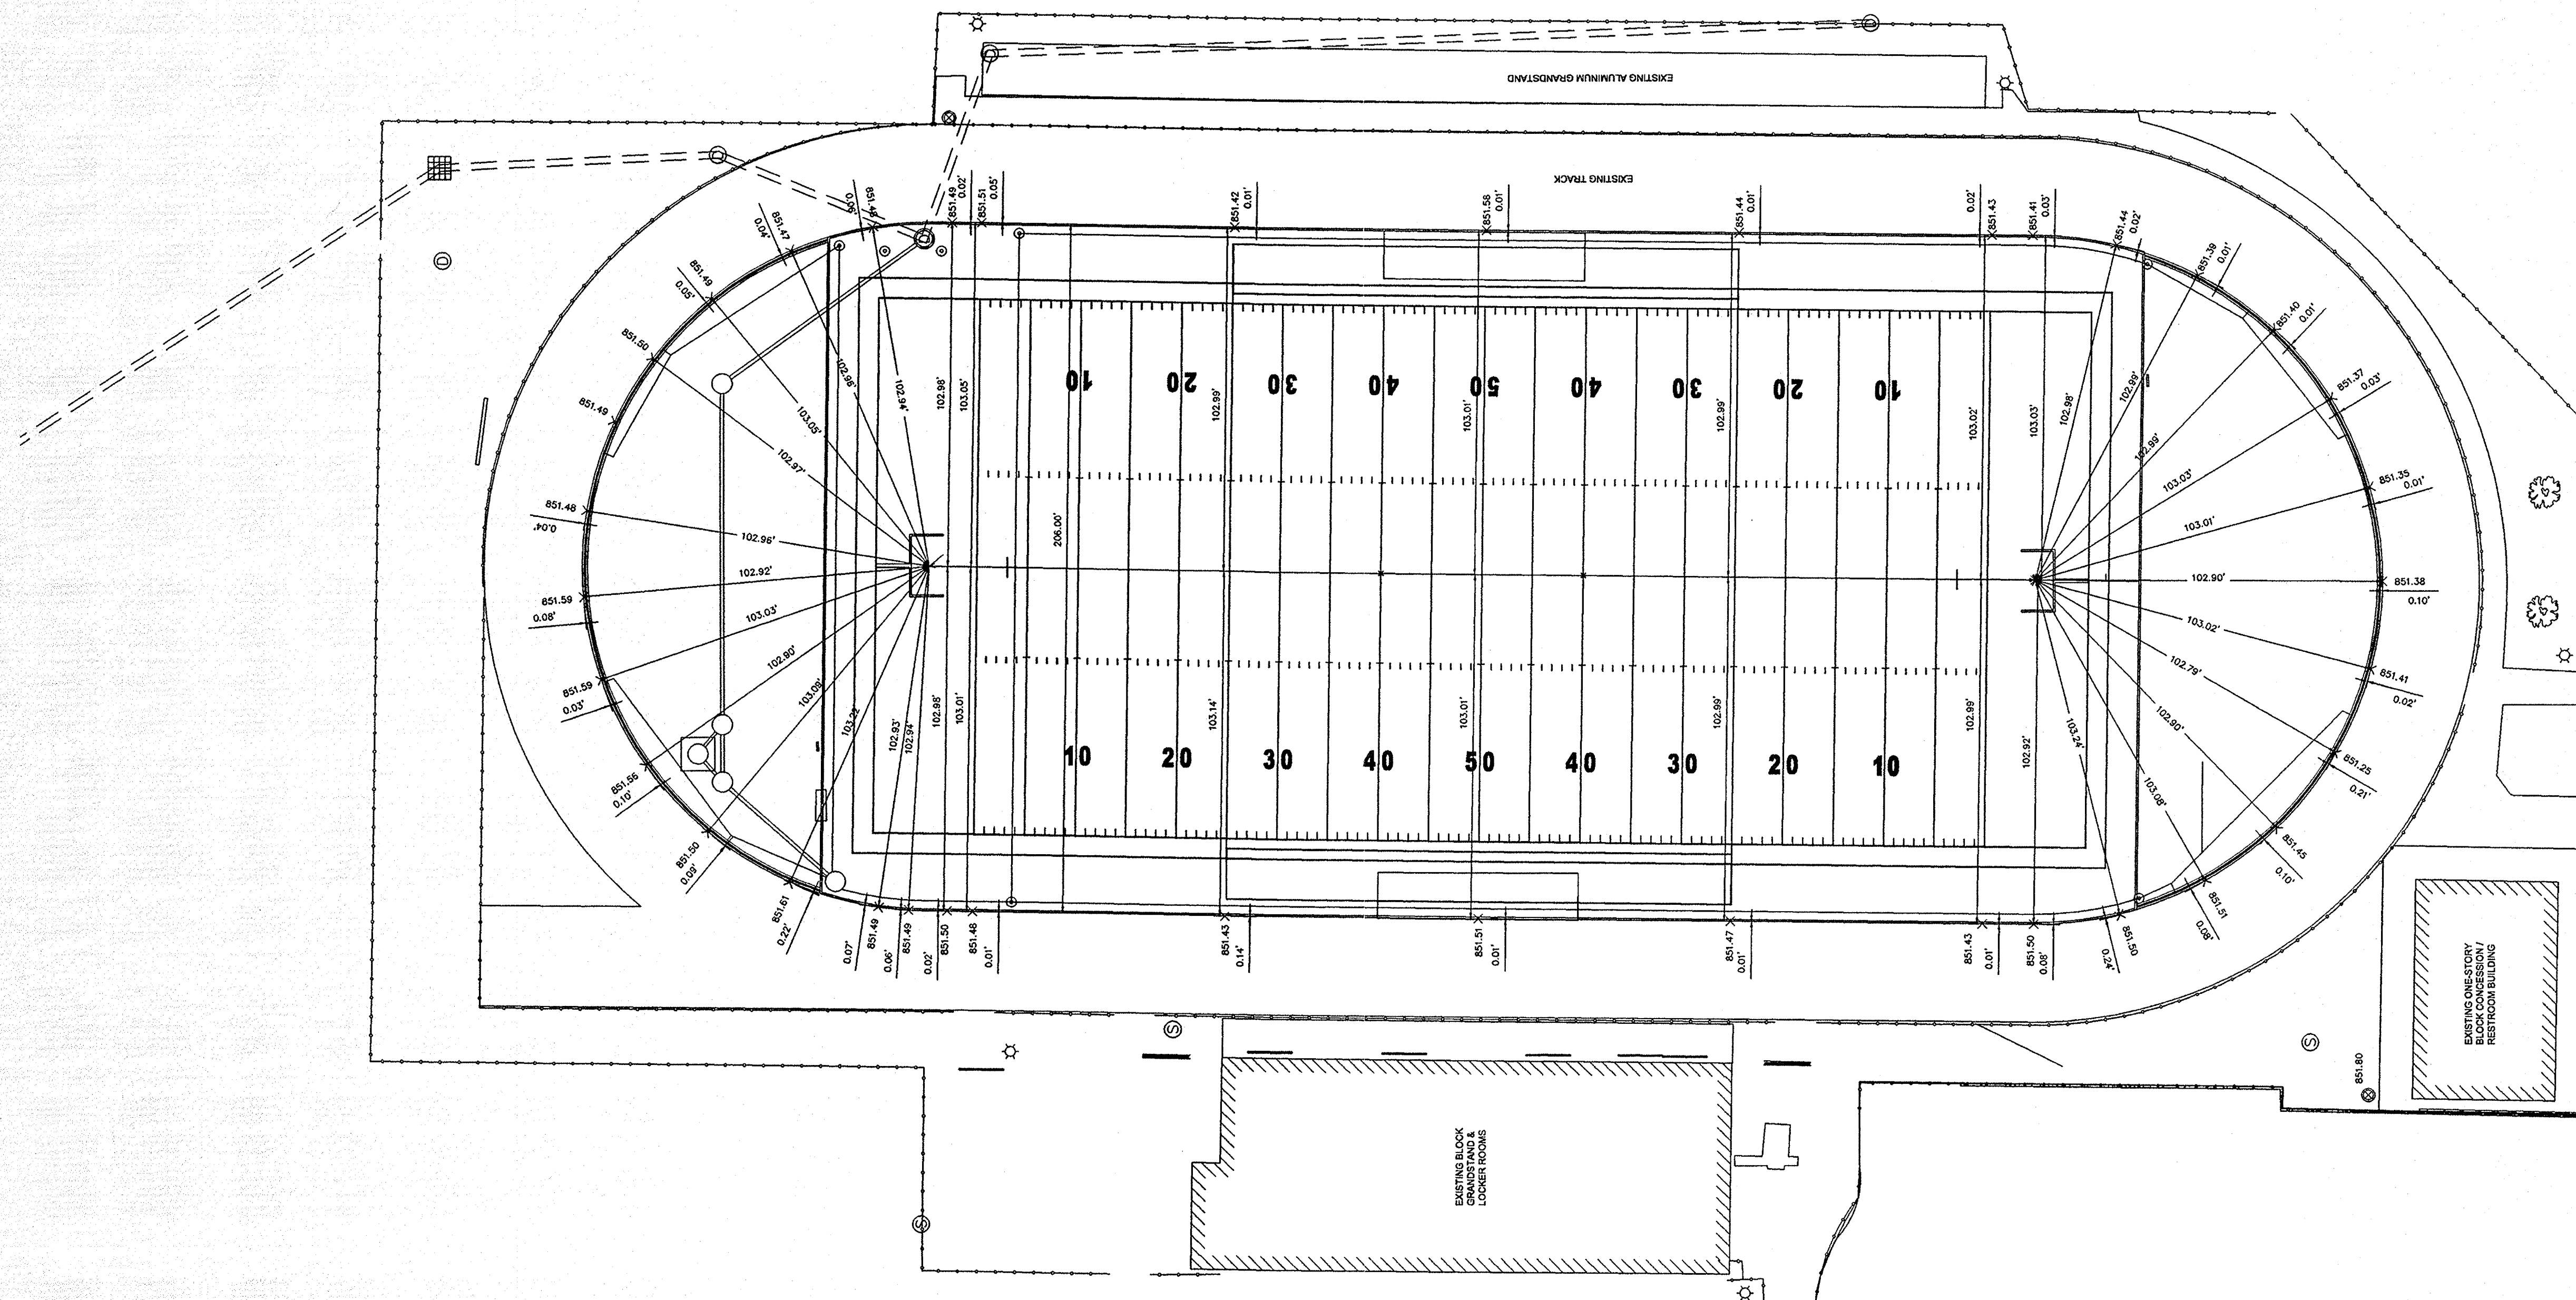

FACE OF CURB / SAWCUT ASBUILT

Brian Riemiller

